



Department of Alternative
Energy Development and Efficiency
MINISTRY OF ENERGY

KLONG LAM PLOK HYDROPOWER PROJECT

YAN TA KHAO DISTRICT TRANG PROVINCE

CONTRACT C1

CIVIL WORKS AND TRANSMISSION LINE

VOLUME 4

DRAWINGS




P&C MANAGEMENT CO.,LTD.

KLONG LAM PLOK HYDROPOWER PROJECT
CONTRACT C1 : LIST OF DRAWINGS



SHEET NO.	DRAWING NO.	DRAWING DETAILS
GENERAL DRAWING		
1	KLP-GN-01	PROJECT LOCATION MAP
2	KLP-GN-02	PROJECT LAY-OUT
3	KLP-GN-03	SYMBOLS, ABBREVIATIONS, AND GENERAL NOTES
4	KLP-GN-04	PROJECT INFORMATION HYDROLOGY DATA
5	KLP-GN-05	POWER WATERWAY HYDRAULIC ARRANGEMENT
6	KLP-GN-06	GEOLOGICAL, PLAN
7	KLP-GN-07	GEOLOGICAL, PROFILE (SHEET 1/3)
8	KLP-GN-08	GEOLOGICAL, PROFILE (SHEET 2/3)
9	KLP-GN-09	GEOLOGICAL, PROFILE (SHEET 3/3)
WEIR		
10	KLP-WE-01	WEIR : WEIR REHABILITATION GENERAL LAY-OUT
11	KLP-WE-02	WEIR : WEIR REHABILITATION SECTION AND DETAILS
12	KLP-WE-03	WEIR : WEIR REHABILITATION SERVICE BRIDGE
13	KLP-WE-04	WEIR : INTAKE STRUCTURE PLAN AND SECTIONS
14	KLP-WE-05	WEIR : INTAKE STRUCTURE SECTIONS
15	KLP-WE-06	WEIR : INTAKE STRUCTURE REINFORCEMENT DETAILS (SHEET 1/2)
16	KLP-WE-07	WEIR : INTAKE STRUCTURE REINFORCEMENT DETAILS (SHEET 2/2)
17	KLP-WE-08	WEIR : INTAKE STRUCTURE MISCELLANEOUS DETAILS
18	KLP-WE-09	WEIR : INTAKE STRUCTURE 1.50x1.50 m. VERTICAL GATE (GATE INSTALLATION)
19	KLP-WE-10	WEIR : INTAKE STRUCTURE 1.50x1.50 m. VERTICAL GATE (GATE DATAL)
20	KLP-WE-11	WEIR : INTAKE STRUCTURE DIA. 1.50 m. VERTICAL GATE
21	KLP-WE-12	WEIR : INTAKE STRUCTURE PEDESTAL SCREW LIFT CAPACITY 6.5 TONS
22	KLP-WE-13	WEIR : INTAKE STRUCTURE GATE-LIFT PEDESTALS
23	KLP-WE-14	WEIR : INTAKE STRUCTURE VERTICAL SCREW-LIFT CAPACITY 2,250 KG.
HEADRACE		
24	KLP-HR-01	PLAN OF DEMOLITION WORK, STA. 0+000 TO STA. 1+000
25	KLP-HR-02	PLAN OF DEMOLITION WORK, STA. 1+000 TO STA. 1+459.508
26	KLP-HR-03	PLAN AND PROFILE, STA. 0+000 TO STA. 0+500
27	KLP-HR-04	PLAN AND PROFILE, STA. 0+500 TO STA. 1+000
28	KLP-HR-05	PLAN AND PROFILE, STA. 1+000 TO STA. 1+459.508
29	KLP-HR-06	TYPICAL SECTIONS AND DETAILS
30	KLP-HR-07	STEEL PIPE AND JOINT DETAILS
31	KLP-HR-08	CONCRETE PIER SECTION AND DETAILS
32	KLP-HR-09	FITTINGS FOR STEEL PIPE
33	KLP-HR-10	ROAD CROSSING, STA 0+252.50 PLAN
34	KLP-HR-11	ROAD CROSSING, STA 0+252.50 SECTIONS
35	KLP-HR-12	ROAD CROSSING, STA 1+173.758 PLAN AND SECTIONS
36	KLP-HR-13	DRAIN CULVERT, STA. 0+108.180 PLAN AND SECTION
37	KLP-HR-14	DRAIN CULVERT, STA. 0+191.773 PLAN AND SECTION
38	KLP-HR-15	DRAIN CULVERT, STA. 0+505.861 PLAN AND SECTION
39	KLP-HR-16	DRAIN CULVERT STA. 0+647.684 , PLAN AND SECTION
40	KLP-HR-17	DRAIN CULVERT STA. 0+830.169 , PLAN AND SECTION
41	KLP-HR-18	DRAIN CULVERT STA. 1+026.360 , PLAN AND SECTION
42	KLP-HR-19	DRAIN CULVERT STA. 1+150.523 , PLAN AND SECTION
43	KLP-HR-20	DRAIN CULVERT STA. 1+381.985 , PLAN AND SECTION
44	KLP-HR-21	DRAIN CULVERT DETAILS OF REINFORCEMENT SHEETS 1 OF 2
45	KLP-HR-22	DRAIN CULVERT DETAILS OF REINFORCEMENT SHEETS 2 OF 2
O&M ROAD		
46	KLP-OM-01	PLAN AND PROFILE, STA. 0+000 TO STA. 0+107.621
47	KLP-OM-02	TYPICAL SECTIONS
SURGE TANK		
48	KLP-ST-01	GENERAL LAY-OUT
49	KLP-ST-02	SECTIONS
50	KLP-ST-03	LADDER RUNG DETAILS 1
51	KLP-ST-04	LADDER RUNG DETAILS 2
52	KLP-ST-05	RING GRIDER AND RAILING FALL DETAILS
53	KLP-ST-06	REINFORCEMENT DETAILS
54	KLP-ST-07	EMERGENCY VALVE CHAMBER PLAN SECTIONS AND DETAILS
55	KLP-ST-08	EMERGENCY VALVE CHAMBER REINFORCEMENT DETAILS
56	KLP-ST-09	SEDIMENT VALVE CHAMBER PLAN SECTIONS AND DETAILS

SHEET NO.	DRAWING NO.	DRAWING DETAILS
57	KLP-ST-10	SEDIMENT VALVE CHAMBER REINFORCEMENT DETAILS
58	KLP-ST-11	SEDIMENT OUTLET PLAN SECTION AND DETAILS
PENSTOCK		
59	KLP-PS-01	PLAN AND PROFILE, STA. 0+000 TO STA. 0+500
60	KLP-PS-02	PLAN AND PROFILE, STA. 0+500 TO STA. 0+693.571
61	KLP-PS-03	THRUST BLOCK PLAN ,SECTIONS REINFORCEMENT DETAILS 1/5
62	KLP-PS-04	THRUST BLOCK PLAN ,SECTIONS REINFORCEMENT DETAILS 2/5
63	KLP-PS-05	THRUST BLOCK PLAN ,SECTIONS REINFORCEMENT DETAILS 3/5
64	KLP-PS-06	THRUST BLOCK PLAN ,SECTIONS REINFORCEMENT DETAILS 4/5
65	KLP-PS-07	THRUST BLOCK PLAN ,SECTIONS REINFORCEMENT DETAILS 5/5
66	KLP-PS-08	PIPE SUPPORT SECTIONS AND DETAILS
67	KLP-PS-09	WYE, PLAN, SECTIONS AND DETAILS AT STA.0+516.909
68	KLP-PS-10	WYE, PLAN, SECTIONS AND DETAILS AT STA.0+678.000
69	KLP-PS-11	EXPANSION JOINT, PLAN, SECTIONS AND DETAILS
70	KLP-PS-12	BEND DETAILS
71	KLP-PS-13	WELDING DETAILS
72	KLP-PS-14	ROAD CROSSING STA 0+356.385 PLAN, SECTIONS REINFORCEMENT
POWER HOUSE		
73	KLP-PH-01	GENERAL LAY-OUT
74	KLP-PH-02	PLAN 1st FLOOR
75	KLP-PH-03	PLAN 2st AND ROOF PLAN
76	KLP-PH-04	ELEVATIONS
77	KLP-PH-05	SECTIONS (SHEET 1/2)
78	KLP-PH-06	SECTIONS (SHEET 2/2)
79	KLP-PH-07	DETAILS OF TOILET, AND BUCKET TREATS
80	KLP-PH-08	DETAIL OF DOORS, WINDOWS AND NAME PLATE
81	KLP-PH-09	PLAN OF FOOTING AND DETAILS
82	KLP-PH-10	PLAN OF SLAB AND DETAILS (1/2)
83	KLP-PH-11	PLAN OF SLAB AND DETAILS (2/2)
84	KLP-PH-12	BEAMS DETAILS
85	KLP-PH-13	BEAMS DETAILS AND STEEL STAIR
86	KLP-PH-14	COLUMN BRACKET AND STAIR DETAILS
87	KLP-PH-15	ROOF BEAM AND TRUSS PLANS
88	KLP-PH-16	TRUSS DETAIL (1/2)
89	KLP-PH-17	TRUSS DETAIL (2/2)
90	KLP-PH-18	DITCH AND MANHOLE DETAILS
91	KLP-PH-19	CABLE TRENCH DETAILS
92	KLP-PH-20	ELECTRIC AND LIGHTING SYSTEMS (SHEET 1/4)
93	KLP-PH-21	ELECTRIC AND LIGHTING SYSTEMS (SHEET 2/4)
94	KLP-PH-22	ELECTRIC AND LIGHTING SYSTEMS (SHEET 3/4)
95	KLP-PH-23	ELECTRIC AND LIGHTING SYSTEMS (SHEET 4/4)
96	KLP-PH-24	GROUNDING SYSTEMS
TAILRACE		
97	KLP-TR-01	GENERAL LAY-OUT
98	KLP-TR-02	SECTIONS AND DETAILS
99	KLP-TR-03	REINFORCEMENT DETAILS
100	KLP-TR-04	1.25x1.25 m. VERTICAL GATE GATE INSTALLATION
101	KLP-TR-05	1.25x1.25 m. VERTICAL GATE GATE DETAIL
TRANSMISSION LINE		
102	KLP-TS-01	GENERAL PLAN
103	KLP-TS-02	PLAN AND PROFILE, STA. 0+000 TO STA. 0+600
104	KLP-TS-03	PLAN AND PROFILE, STA. 0+600 TO STA. 1+200
105	KLP-TS-04	PLAN AND PROFILE, STA. 1+200 TO STA. 1+386
106	KLP-TS-05	POLE TYPE "A" AND "B"
107	KLP-TS-06	POLE TYPE "C" AND "D"
108	KLP-TS-07	POLE TYPE "E"
109	KLP-TS-08	POLE TYPE "F" AND "G"
110	KLP-TS-09	TYPE OF ANCHOR GUY

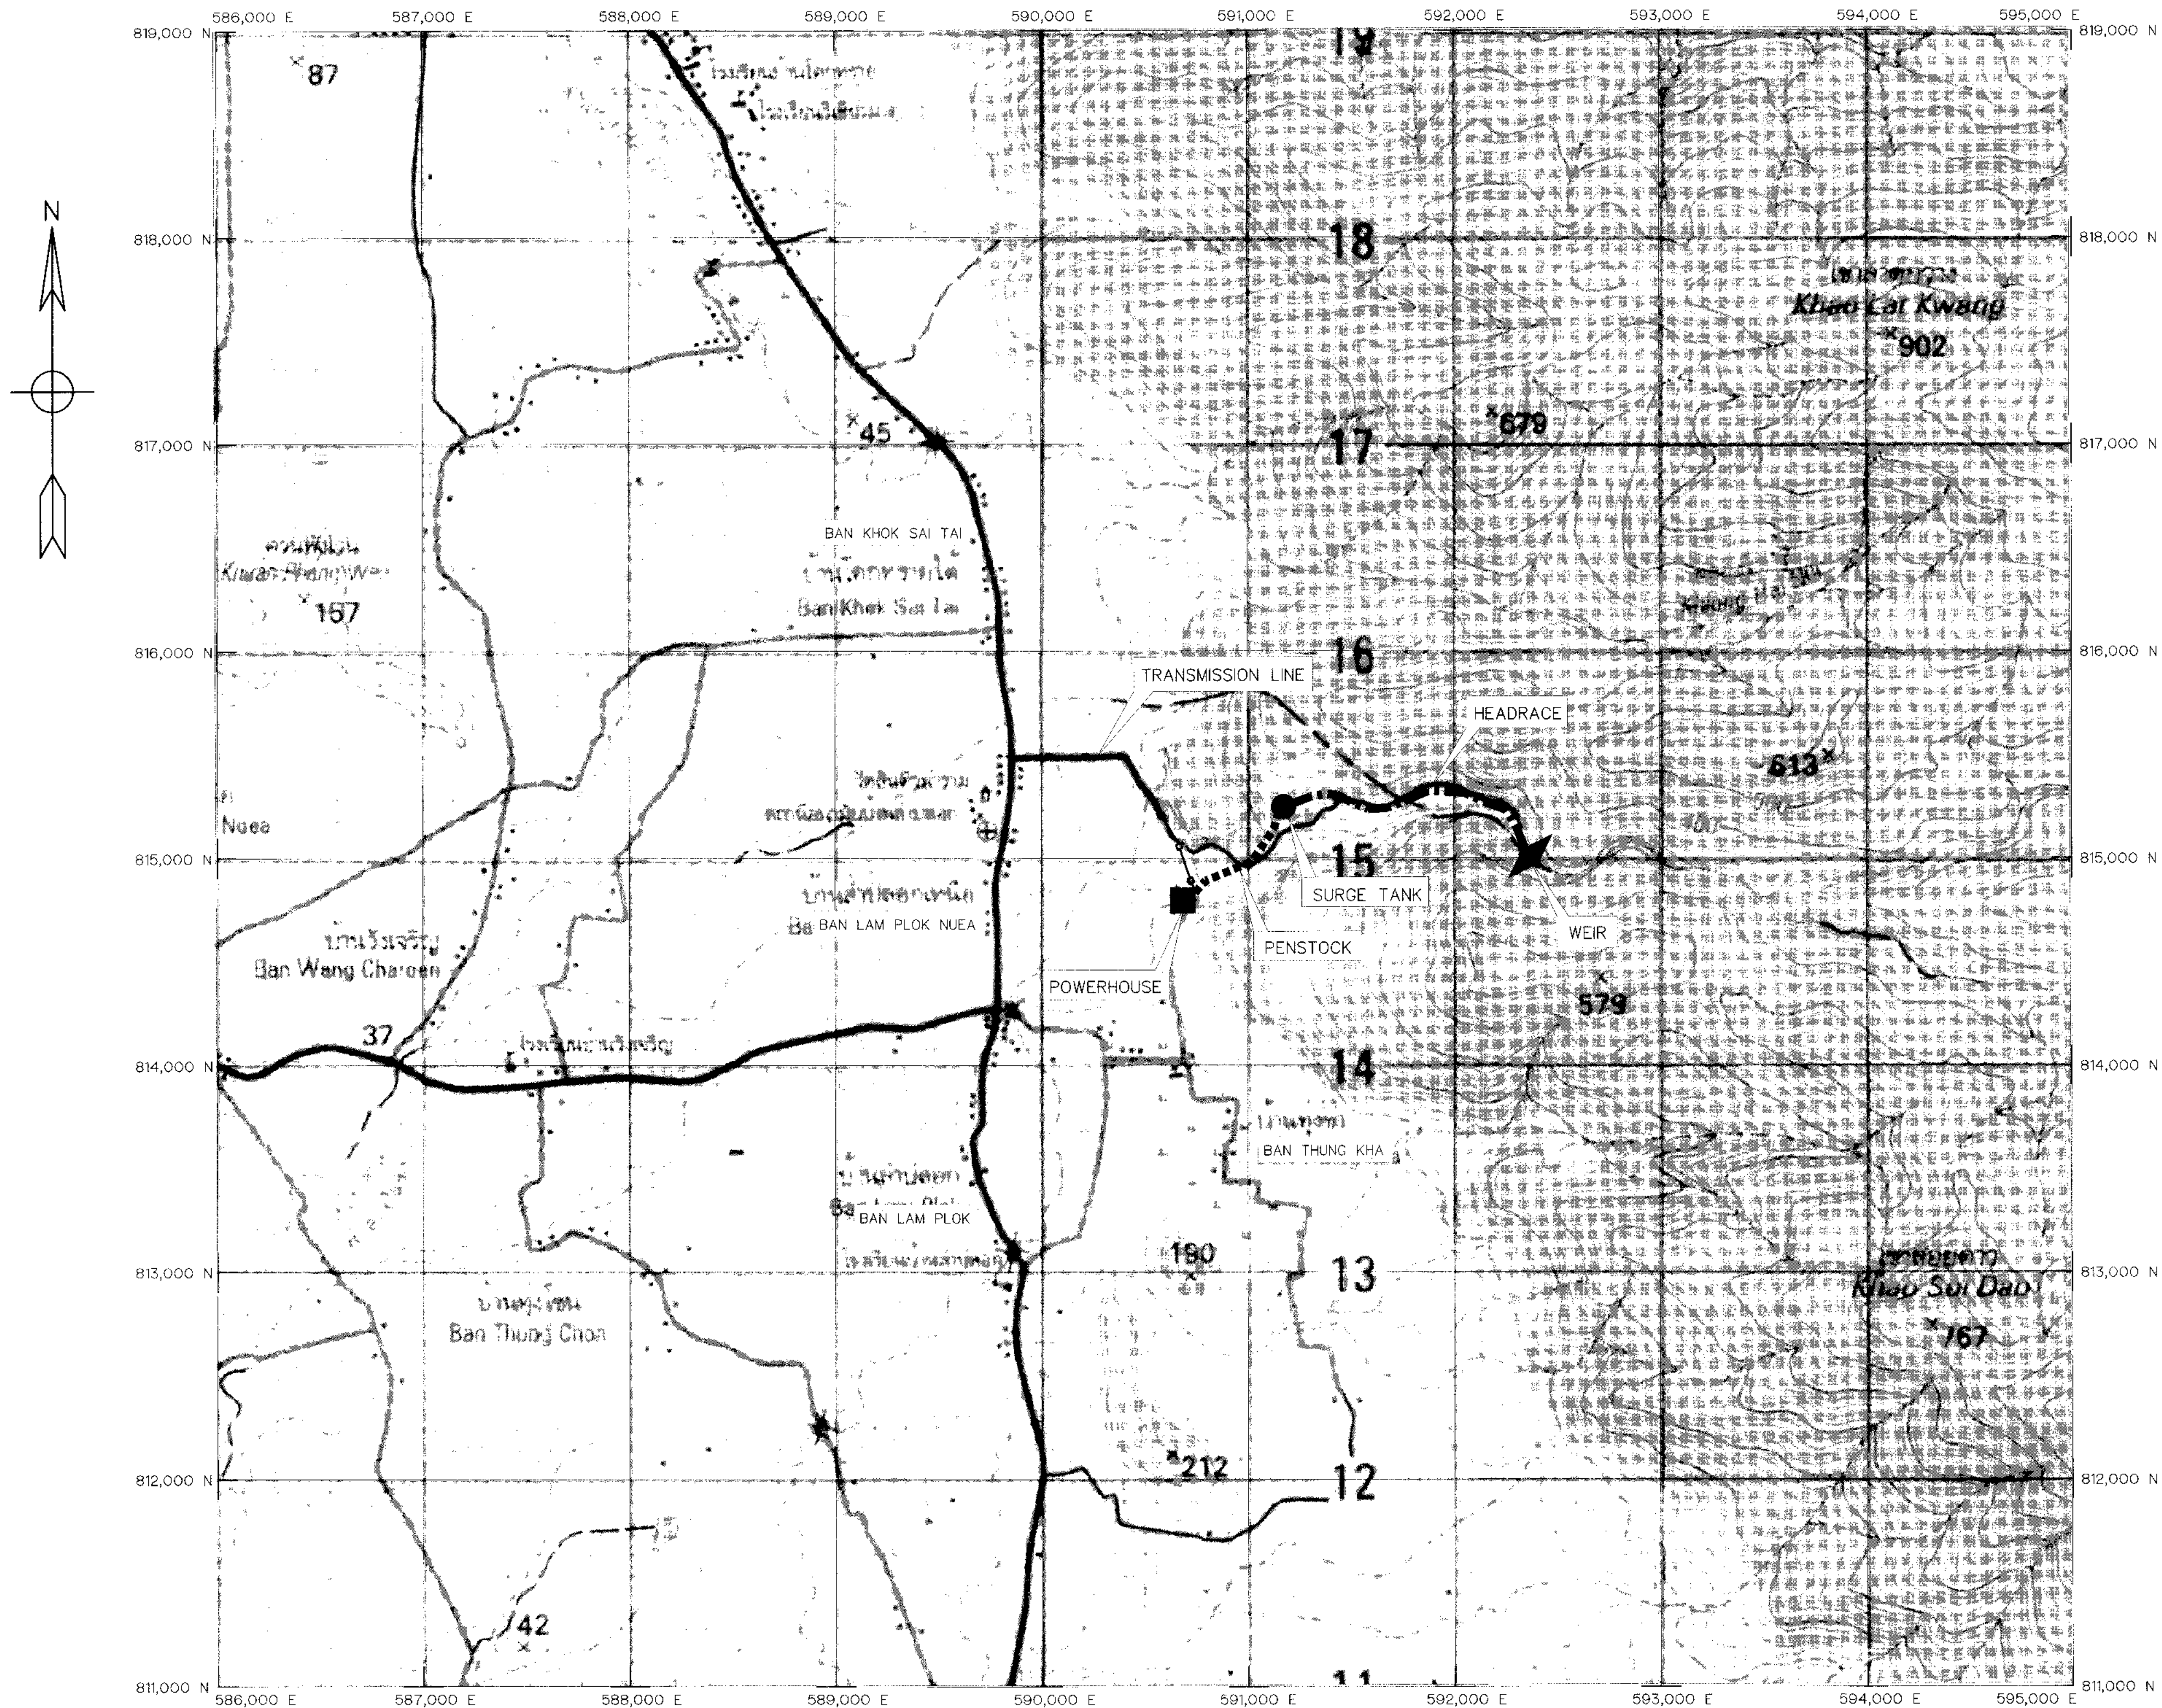

PROJECT AREA MAP
SCALE 1:20,000

 
- NOTES :
1. ALL DIMENSIONS AND ELEVATIONS (M.S.L.) ARE IN METERS, UNLESS OTHERWISE SHOWN
 2. SYMBOLS, ABBREVIATIONS AND GENERAL NOTES SEE DWG. NO. KLP-GN-03

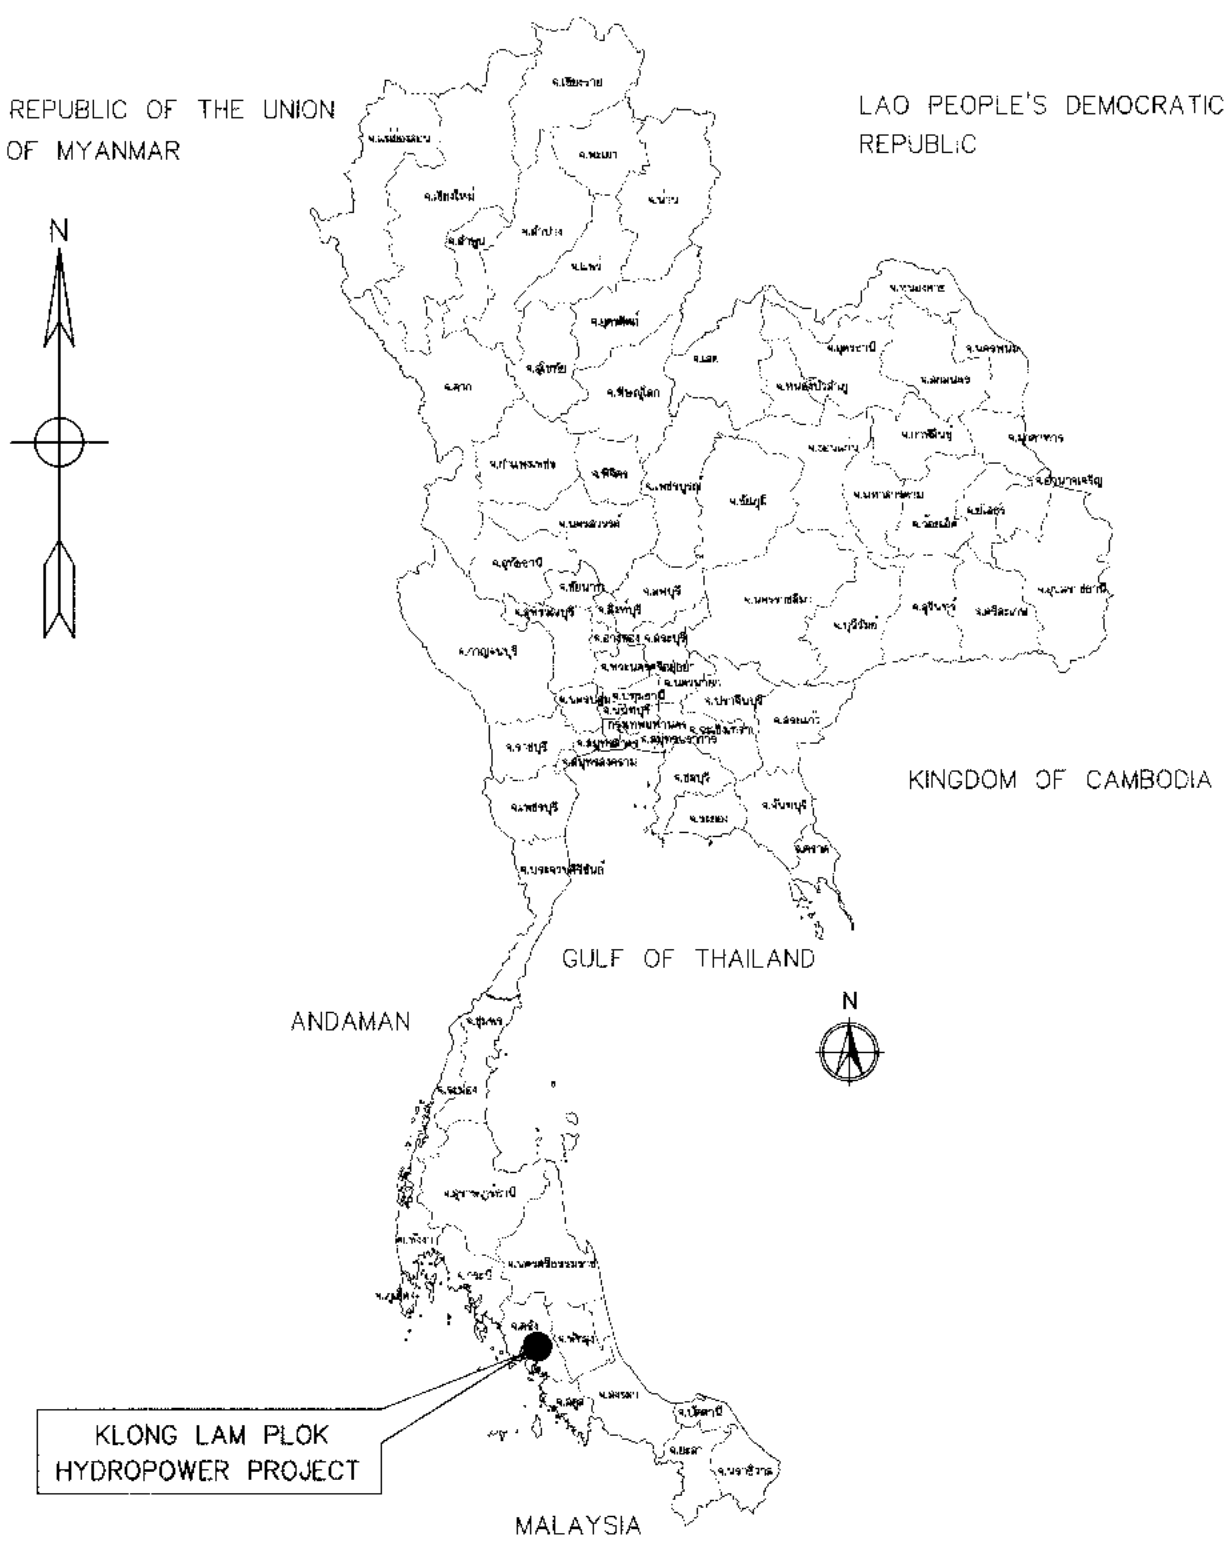

LOCATION MAP
NOT TO SCALE

- LEGENDS :
- STREAM
 - WEIR
 - HEADRACE
 - SURGE TANK
 - PENSTOCK
 - POWERHOUSE
 - ACCESS ROAD
 - TRANSMISSION LINE


KINGDOM OF THAILAND Department of Alternative Energy Development and Efficiency MINISTRY OF ENERGY			
KLONG LAM PLOK HYDROPOWER PROJECT			
CIVIL WORKS AND TRANSMISSION LINE GENERAL DRAWING PROJECT LOCATION MAP			
DESIGNED BY 09129074 09/03/2559 09/03/2559		REVIEWED	
DRAWN BY 09129074 09/03/2559 09/03/2559		RECOMMENDED	
CHECKED BY 09129074 09/03/2559 09/03/2559		APPROVED	
PROJECT MANAGER		DATE	
CONSULTANTS		DEDE	
PROJECT NO.		DRAWING NO.	
09129074		KLP-GN-01	
SHEET NO.		1 OF 110	

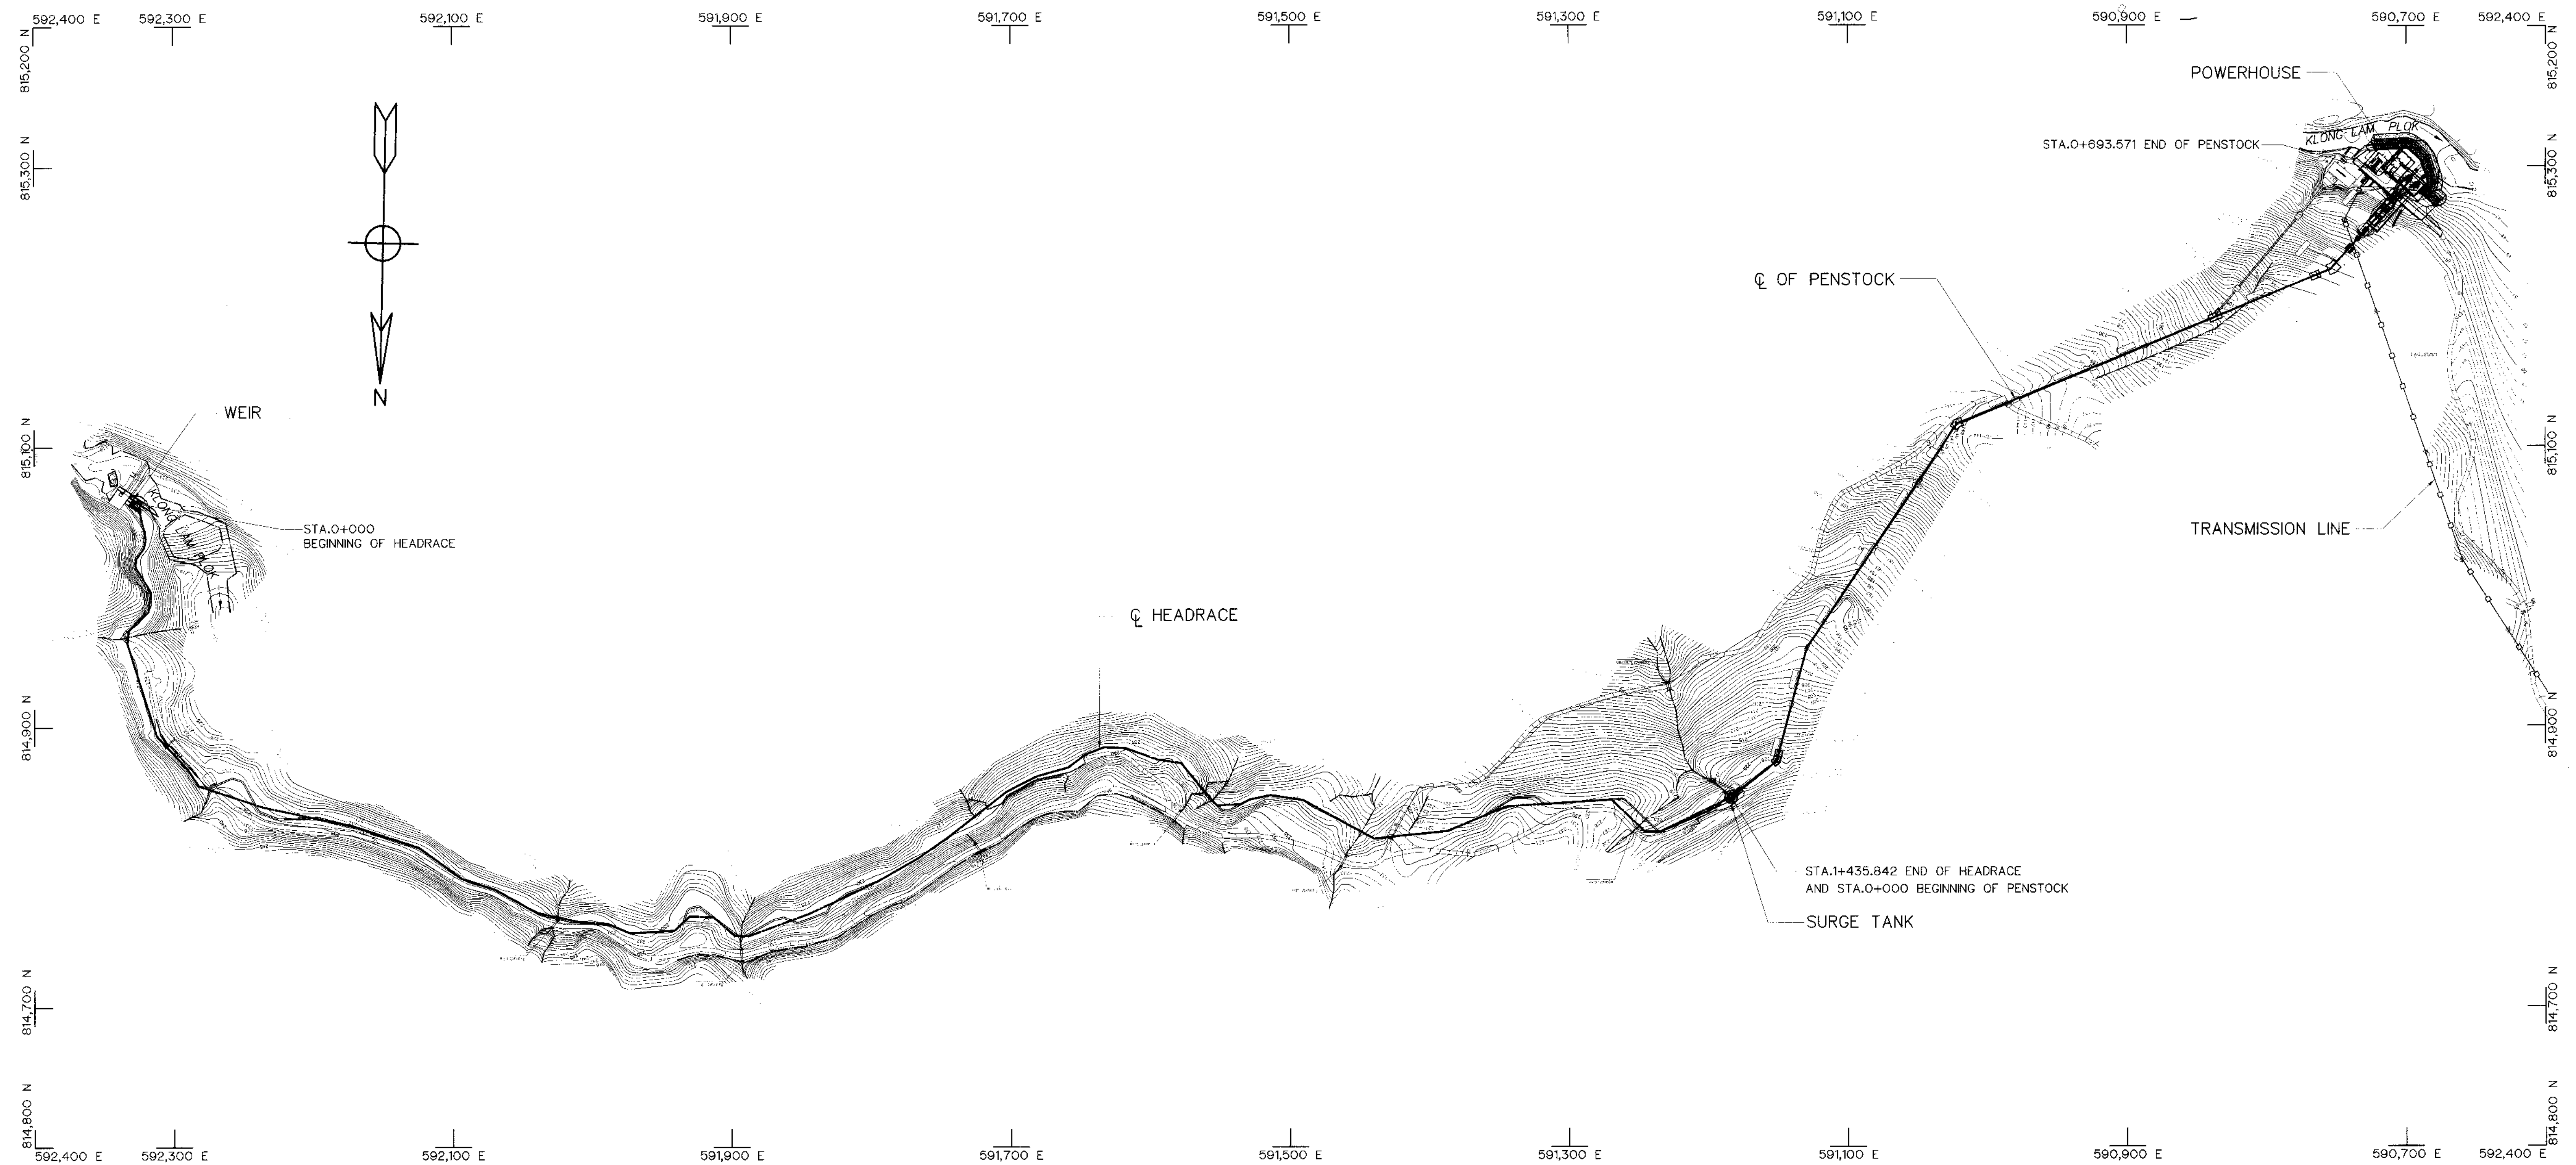

PROJECT LAYOUT
SCALE 1:2,500

NOTES :

1. ALL DIMENSIONS AND ELEVATIONS (M.S.L.) ARE IN METERS, UNLESS OTHERWISE SHOWN.
2. SYMBOLS, ABBREVIATIONS AND GENERAL NOTES SEE DWG. NO. KLP-GN-03

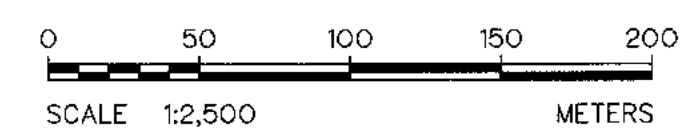

3					KINGDOM OF THAILAND Department of Alternative Energy Development and Efficiency MINISTRY OF ENERGY	
2					KLONG LAM PLOK HYDROPOWER PROJECT	
1					CIVIL WORKS AND TRANSMISSION LINE GENERAL DRAWING PROJECT LAY-OUT	
NO.					P&C MANAGEMENT CO.,LTD.	Department of Alternative Energy Development and Efficiency MINISTRY OF ENERGY
DATE					DESIGNED 11/29/07 08/03/2559	REVIEWED
REVISIONS					DRAWN	SUBMITTED
CHECKED					CHECKED 08/03/2559	RECOMMENDED
APPROVED					APPROVED	APPROVED
CONSULTANTS					PROJECT MANAGER	DRAWING NO.
DEDE					DATE	KLP-GN-02
						SHEET NO.
						2 OF 110

ABBREVIATIONS :

A	CROSS-SECTION AREA OF FLOW	MAX.	MAXIMUM
AC.	ASBESTOS CEMENT PIPE	M.S.L.	MEAN SEA LEVEL
AGG.	AGGREGATE	MISC.	MISCELLANEOUS
ALT.	ALTERNATIVE	N.	NORTH
APPROX.	APPROXIMATE	n.	MANNING'S ROUGHNESS COEFFICIENT
AZ.	AZIMUTH	N.F.	NEAR FACE
B.	BEGINNING OF SURVEY	NGL.	NATURAL GROUND LEVEL
BC.	BEGINNING OF CURVE	NO. OR #	NUMBER
BEG.	BEGINNING	N.W.L.	NORMAL WATER LEVEL
BF.	BOTTOM FACE	OD.	OUTSIDE DIAMETER
B	BEAM	O.F.	OUTSIDE FACE
B.M.	BENCH MARK	O&M	OPERATION & MAINTENANCE
BOTT.	BOTTOM	PC.	POINT OF HONRIZONTAL CURVATURE
BRG.	BEARING	PI.	POINT OF HORIZONTAL INTERSECTION
C.B.R.	CALIFORNIA BEARING RATIO	PL.	PLATE
C/C	CENTER TO CENTER	P.O.C.	POINT ON CURVE
CL	CENTER LINE	P.O.T.	POINT ON TANGENT
CL.	CLEARANCE	P.O.S.T.	POINT ON SUB-TANGENT
CM. OR cm.	CENTIMETER	PRC.	POINT OF HORIZONTAL REVERSE CURVE
CM./S OR cm./s	CENTIMETER PER SECOND	PT.	POINT OF TANGENT
COL.	COLUMN	PVC.	POLYVINYL CHLORIDE
CONC.	CONCRETE	PVC.	POINT OF VERTICAL CURVATURE
D	DEGREE OF CURVE	PVI.	POINT OF VERTICAL INTERSECTION
DB.	DEFORM BAR	PVRC.	POINT OF VERTICAL REVERSE CURVE
d.	DEPTH OF WATER	PVT.	POINT OF VERTICAL TANGENT
DIA. OR Ø	DIAMETER	Q.	DISCHARGE
DOH.	DEPARTMENT OF HIGHWAY	QTY. QUAN.	QUANTITY
DWG.	DRAWING	R	RADIUS OF CURVATURE
DEDE.	DEPARTMENT OF ALTERNATIVE ENERGY	r	HYDRAULIC RADIUS
	DEVELOPMENT AND EFFICIENCY	RØ , Ø	ROUND BAR
E	EAST	RC.	REINFORCED CONCRETE
E	END OF SURVEY	RD.	ROAD
EA.	EACH	REF.	REFERENCE
E.C.	END OF CURVE	REINF.	REINFORCEMENT
E.F.	END OF FACE	REQ'D	REQUIRED
EL. OR ELEV.	ELEVATION	RD.	ROYAL IRRIGATION DEPARTMENT
EXIST.	EXISTING	SCH.	SCHEDULE
EXP.	EXPANSION	SE.	SUPERELEVATION
EXT.	EXTERIOR	SETC.	SECTION
EX.	EXTERNAL DISTANCE OF CURVE	S.P.C.T.	STANDARD PROCTOR COMPACTION TEST
f	FREE BOARD , FINISH	S.S.	SIDE SLOPE
F.F.	FAR FACE	STIR.	STIRRUP
F.S.L.	FULL SUPPLY LEVEL	STA.	STATION
FTG.	FOOTING	STD.	STANDARD
HD.	HEAD	STR.	STRUCTURE
HEX.	HEXAGONAL	SYMM.	SYMMETRICAL
HOR.	HORIZONTAL	T.	TANGENT LENGTH , THICKNESS
ID.	INSIDE DIAMETER	T	TON
IF.	INSIDE FACE	THK.	THICKNESS
IN. OR "	INCH	T.F.	TOP FACE
INT.	INTERIOR	T.I.S.	THAI INDUSTRIAL STANDARD
INV.	INVERT	Ts.	SUPERELEVATION TRANSITION LENGTH
Kg.	KILOGRAM	TYP.	TYPICAL
Km.	KILOMETER	V.	VELOCITY OF FLOW
KPH.	KILOMETER PER HOUR	V.C.	VERTICAL CURVE
KSC.	KILOGRAM PER SQUARE CENTIMETER	Vc.	LENGTH OF VERTICAL CURVE
L	LENGTH OF CURVE	VER.	VERTICAL
LC.	LENGTH OF HORIZONTAL CURVE	VOL.	VOLUME
LONG.	LONGITUDINAL	W/	WITH
LT.	LEFT	W.C.	WATER CLOSET
L.W.L.	LOW WATER LEVEL	⊙	ANGLE
M. OR m.	METER	△	DEFLECTION ANGLE
M. ² OR m. ²	SQUARE METER		
M. ³ OR m. ³	CUBIC METER		
MM. OR mm.	MILLIMETER		
M./S OR m./s	METER PER SECOND		
MIN.	MINIMUM		

SYMBOLS :

	TYPICAL NORTH ARROW
	CENTER LINE
	PAVED ROAD
	DIRT ROAD, LATEITE ROAD OR TRACK
	VILLAGE
	CITY OR DISTRICT
	POND OR SWAMP
	CULVERT UNDER ROAD
	BRIDGE
	POLE
	TEST PIT
	HAND AUGER
	EXISTING DRILL HOLES
	DRILL HOLES
	DEGREE, MINUTE, SECOND
	AT EQUAL DISTANCE BETWEEN CENTER TO CENTER
	B.M.
	STATION
	BC., EC., PC., PI., PT., PCV., PVT.
	WATER LEVEL
	PLAN OF RIPRAP
	PLAN OF SLOPE RIPRAP
	SECTION OF DUMPED RIPRAP
	SECTION OF HAND PLACED RIPRAP
	SECTION OF SAND
	SECTION OF GRAVEL OR COARSE AGGREGATE
	SECTION OF ROCK
	SECTION OF EARTH
	SECTION OF BACKFILL
	SECTION OF CONCRETE
	STEEL SECTION
	ELEVATION OR PLAN OF EARTH CUT OR FILL
	ELEVATION OR PLAN OF ROCK CUT
	ELEVATION OR PLAN OF SLOPE
	NATURAL GROUND LEVEL
	CONTOUR LINE
	RIVER, STREAM OR NATURAL DRAIN
	FLOW DIRECTION
	SLOPE DIRECTION
	SLOPE RATIO

GENERAL NOTES :

- ALL DIMENSIONS AND ELEVATIONS (M.S.L.) ARE IN METERS UNLESS OTHERWISE SHOWN.
- DURING THE CONTRUCTION PERIOD, IT IS THE CONTRACTOR'S DUTY TO CHECK THE CORRECTION OF ALL RELEVANT LOCATIONS, DIMENSIONS, ELEVATIONS AND OTHER DATA AS PROVIDED BY THE DRAWING AND TECHNICAL SPECIFICATIONS BEFORE THE IMPLEMENTATION OF THE WORKS.
- IN CASE OF ANY DETAILS BEING NOT MENTIONED OR NOT SHOWN IN THE DRAWING OR TECHNICAL SPECIFICATIONS, OR IN CASE OF ANY DISCREPANCY, DEFECTIVE DESCRIPTION, ERROR, DIMENSION OR AMBIGUTY BETWEEN OR IN ANY OF THE DRAWINGS, IT IS THE CONTRACTOR'S RESPONSIBILITY TO CORRECT AND/OR ADJUST THE RELEVENT DRAWINGS TO OBTAIN FIELD ENGINEER APPROVAL
- ADDITIONAL SYMBOLS, IF REQUIRED, ARE DEFINED IN THE RESPECTIVE DRAWINGS.
- THE SPECIFICATIONS AND THE QUANTITIES OF MATERIALS ARE SPECIFIED IN THE TECHNICAL SPECIFICATIONS.
- ALL PLAIN CONCRETE CORNERS ARE TO BE CHEMFERED 2 cm. UNLESS OTHERWISE SHOWN.

STRUCTURAL DESIGN NOTES :





- THE ULTIMATE COMPRESSIVE STRENGTH OF CONCRETE OF STANDARD CYLINDER (Ø0.15x0.30 m.) TEST AT AGE 28 DAYS SHALL BE AS THE FOLLOWING, UNLESS OTHERWISE SHOWN.

fc' (ksc)	DESCRIPTION
350	PRESTRESS CONCRETE
210	1. WEIR
	2. SURGE TANK
	3. POWERHOUSE
	4. TAILRACE
	5. MANHOLE
	6. ANCHOR BLOCK, PIPE SUPPORT
	7. HEADRACE
	8. BOX CULVERT
140	LEAN CONCRETE

- UNLESS OTHERWISE SHOWN, THE FOLLOWING CLEAR COVER OF CONCRETE OVER OF THE REINFORCEMENT SHALL BE USED :
 - FACE EXPOSED TO SCOUR 5.0 cm.
 - FACE EXPOSED TO EARTH OR WEATHER 5.0 cm.
 - FACE UNEXPOSED TO EARTH OR WEATHER 3.0 cm.
- THE REINFORCEMENT LAP SPLICES SHALL NOT BE LESS THAN 50 DIAMETERS OF BIGGER THAN BAR WITH HOOKS, UNLESS OTHERWISE SHOWN.
- EMBEDDED METALWORK SHALL BE SECURELY FASTENED IN POSITION BEFORE PLACING CONCRETE.
- ALL CONSTRUCTION JOINT SHOULD BE TREATED AS DIRECTED IN ORDER TO ASSURE THE BEST BOND.
- A 5 cm. (MIN.) LAYER OF LEAN CONCRETE (1:3:5 BY VOLUME) SHOULD BE PLACED BELOW CONCRETE STRUCTURES.
- THE STRUCTURES SHOULD BE PLACED ON UNDISTURBED SOILS OR COMPACTED FILL AND BACKFILL AROUND THE STRUCTURES SHOULD BE COMPACTED.
- THE FOUNDATION ELEVATIONS ARE SUBJECT TO CHANGE AS DIRECTED ACCORDING TO THE SOIL CONDITIONS.
- ALL SIZES OF REINFORCING BARS AND STRUCTURAL STEELS ARE IN MILLIMETERS.
- ALL STRUCTURAL STEELS ARE THOSE OF T.I.S. DESIGNATION Fe24.
- REINFORCED STEEL BARS SHALL BE CONFORM TO T.I.S. AS FOLLOW :
 - DEFORMED BARS (SD30) – T.I.S. 24-2548
 - ROUND BARS (SR24) – T.I.S. 20-2543
- ALLOWABLE BEARING CAPACITY OF FOUNDATION SHALL NOT BE LESS THAN AS FOLLOW :
 - INTAKE $Q_0 = 15 \text{ T/M}^2$
 - HEADRACE $Q_0 = 15 \text{ T/M}^2$
 - SURGE TANK $Q_0 = 20 \text{ T/M}^2$
 - POWERHOUSE $Q_0 = 20 \text{ T/M}^2$
 - PENSTOCK $Q_0 = 20 \text{ T/M}^2$


3				
2				
1				
NO.	DATE	REVISIONS	CHECKED	APPROVED
CONSULTANTS		DEDE		

KINGDOM OF THAILAND Department of Alternative Energy Development and Efficiency MINISTRY OF ENERGY	
KLONG LAM PLOK HYDROPOWER PROJECT	
CIVIL WORKS AND TRANSMISSION LINE GENERAL DRAWING SYMBOLS, ABBREVIATIONS, AND GENERAL NOTES	
P&C MANAGEMENT CO.,LTD.	DEPARTMENT OF ALTERNATIVE ENERGY DEVELOPMENT AND EFFICIENCY MINISTRY OF ENERGY
DESIGNED 210.28074 0.94 210.6226	REVIEWED
DRAWN	RECOMMENDED
CHECKED 210.6226	APPROVED
PROJECT MANAGER 08/03/2559 DATE	DRAWING NO. KLP-GN-03 SHEET NO. 3 OF 110

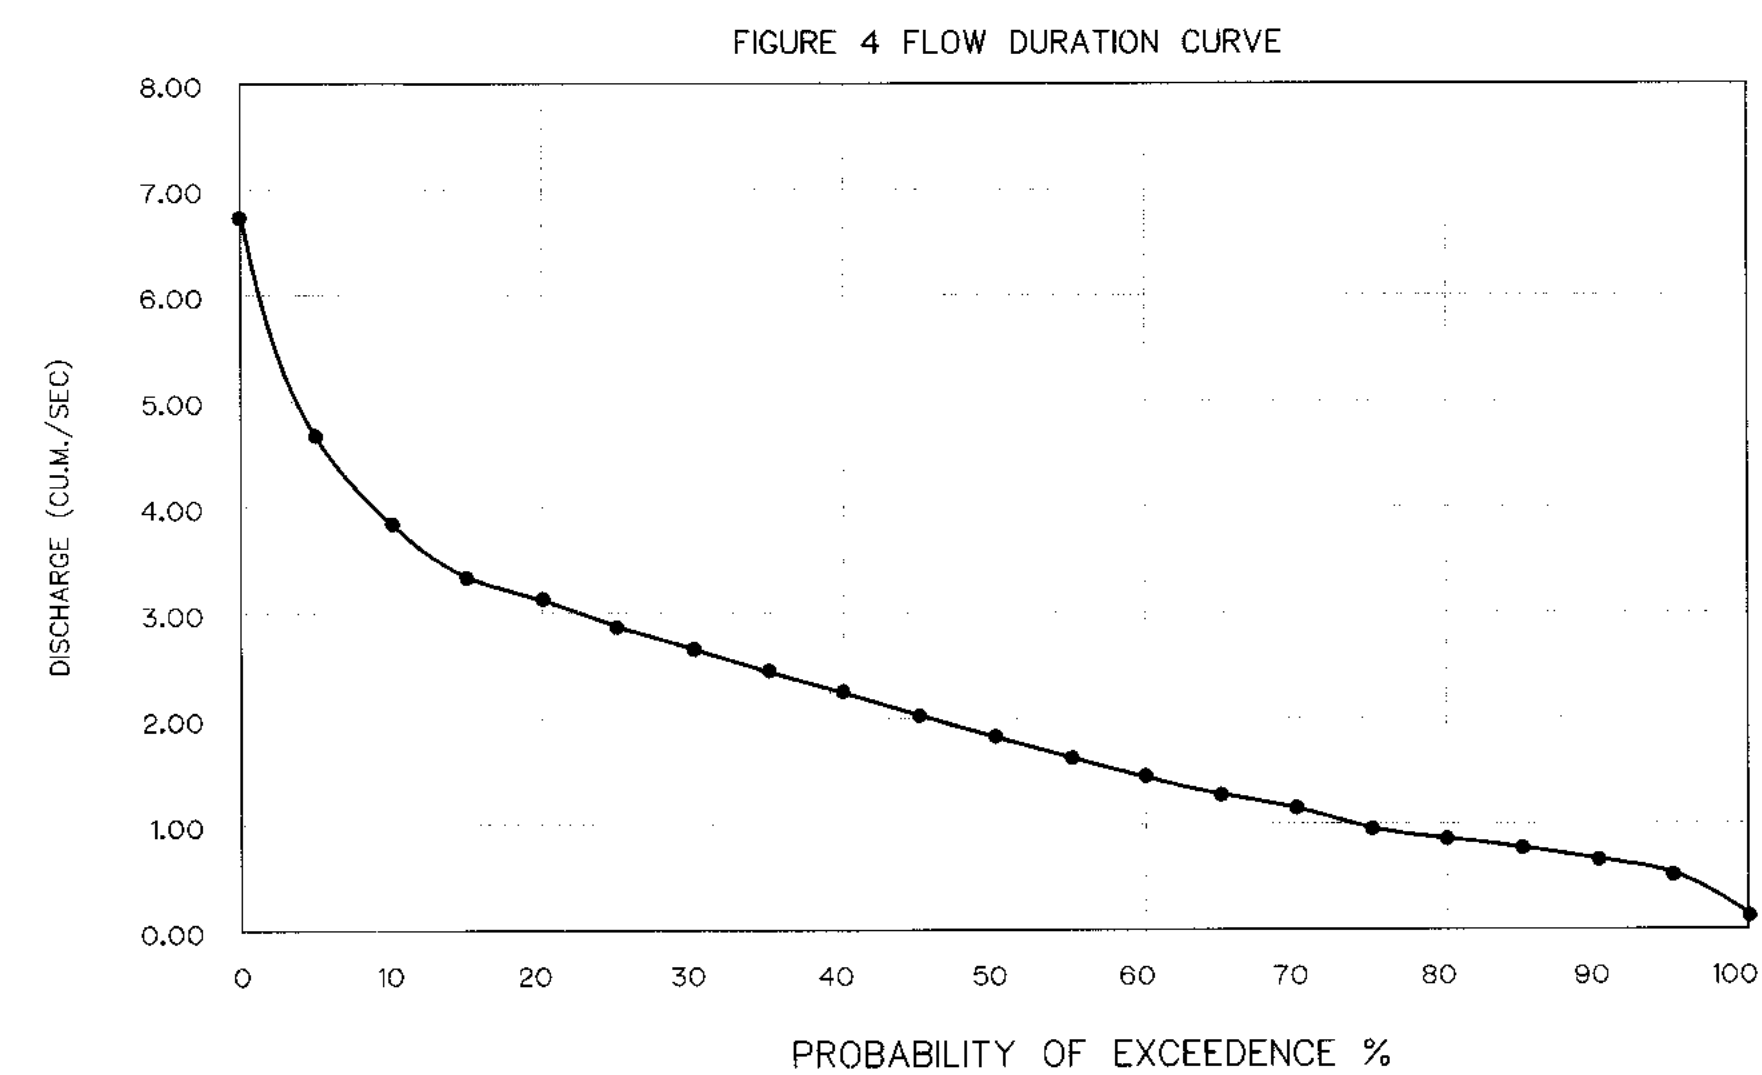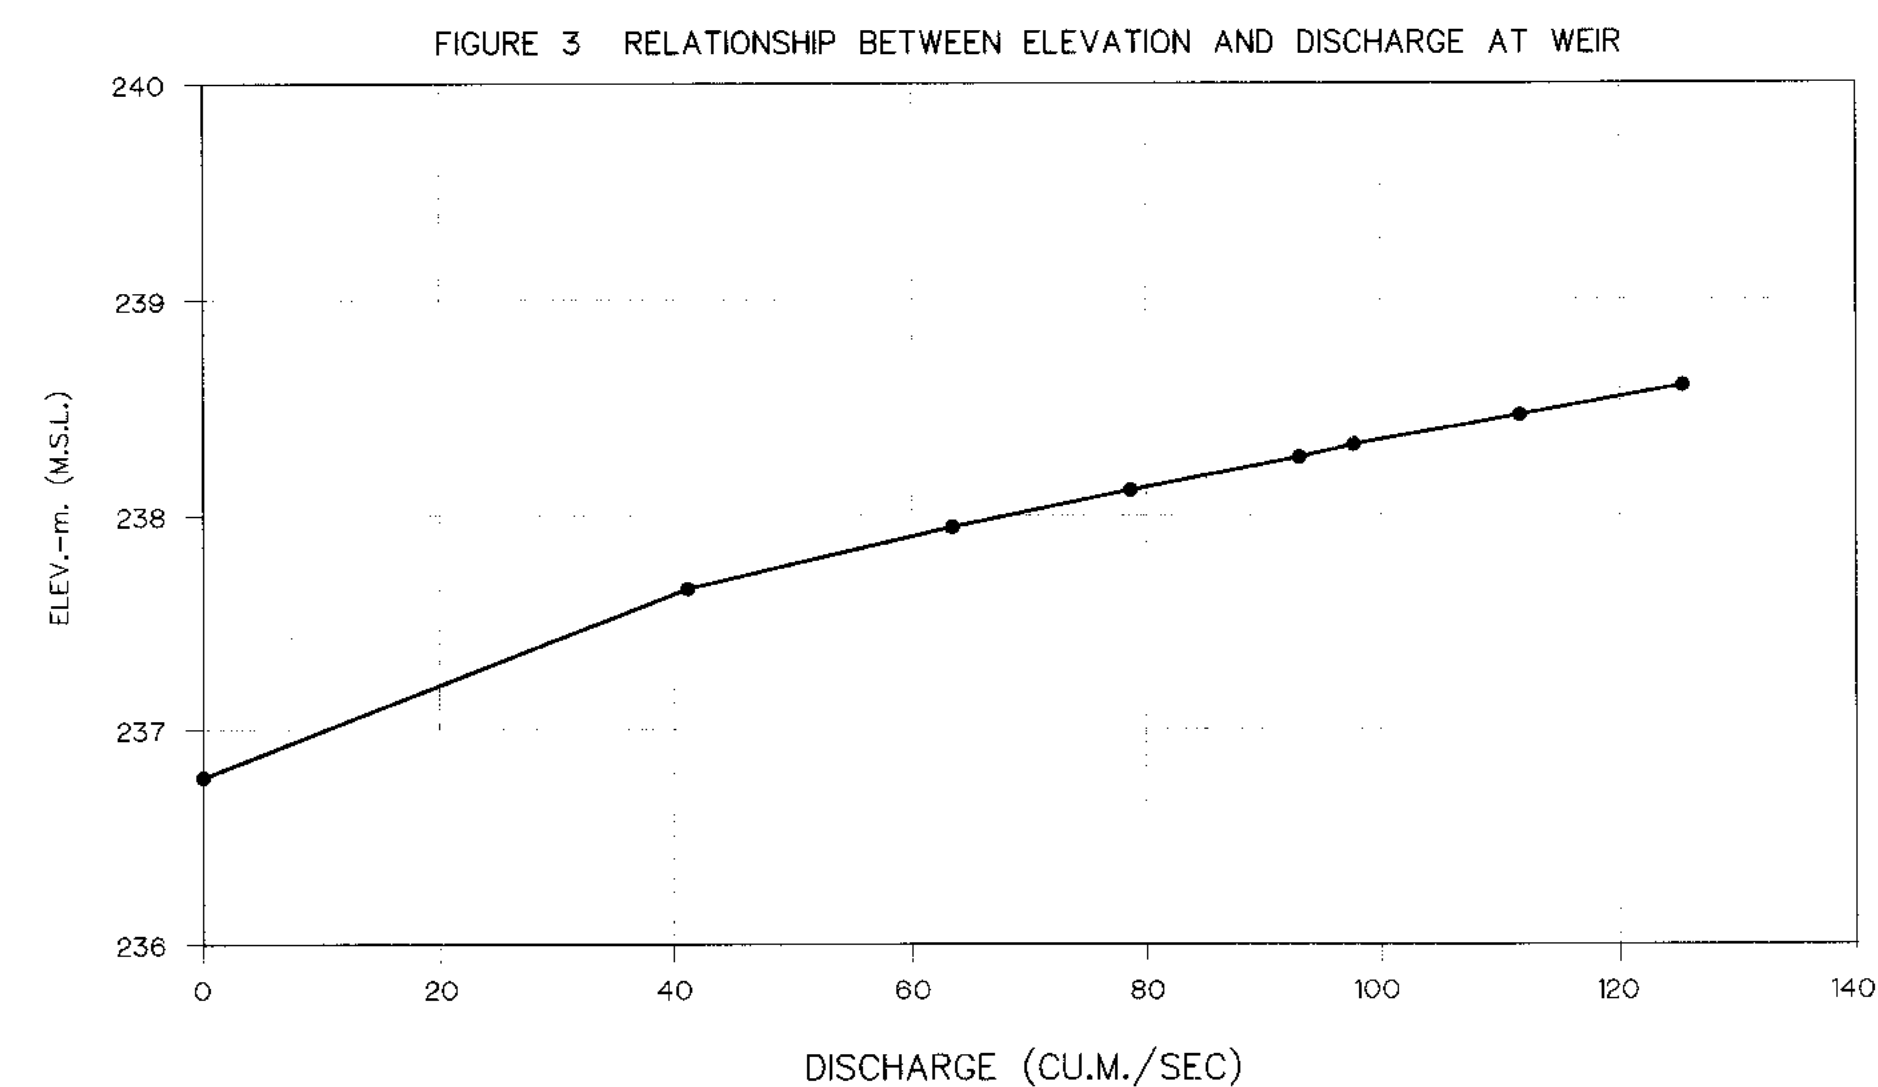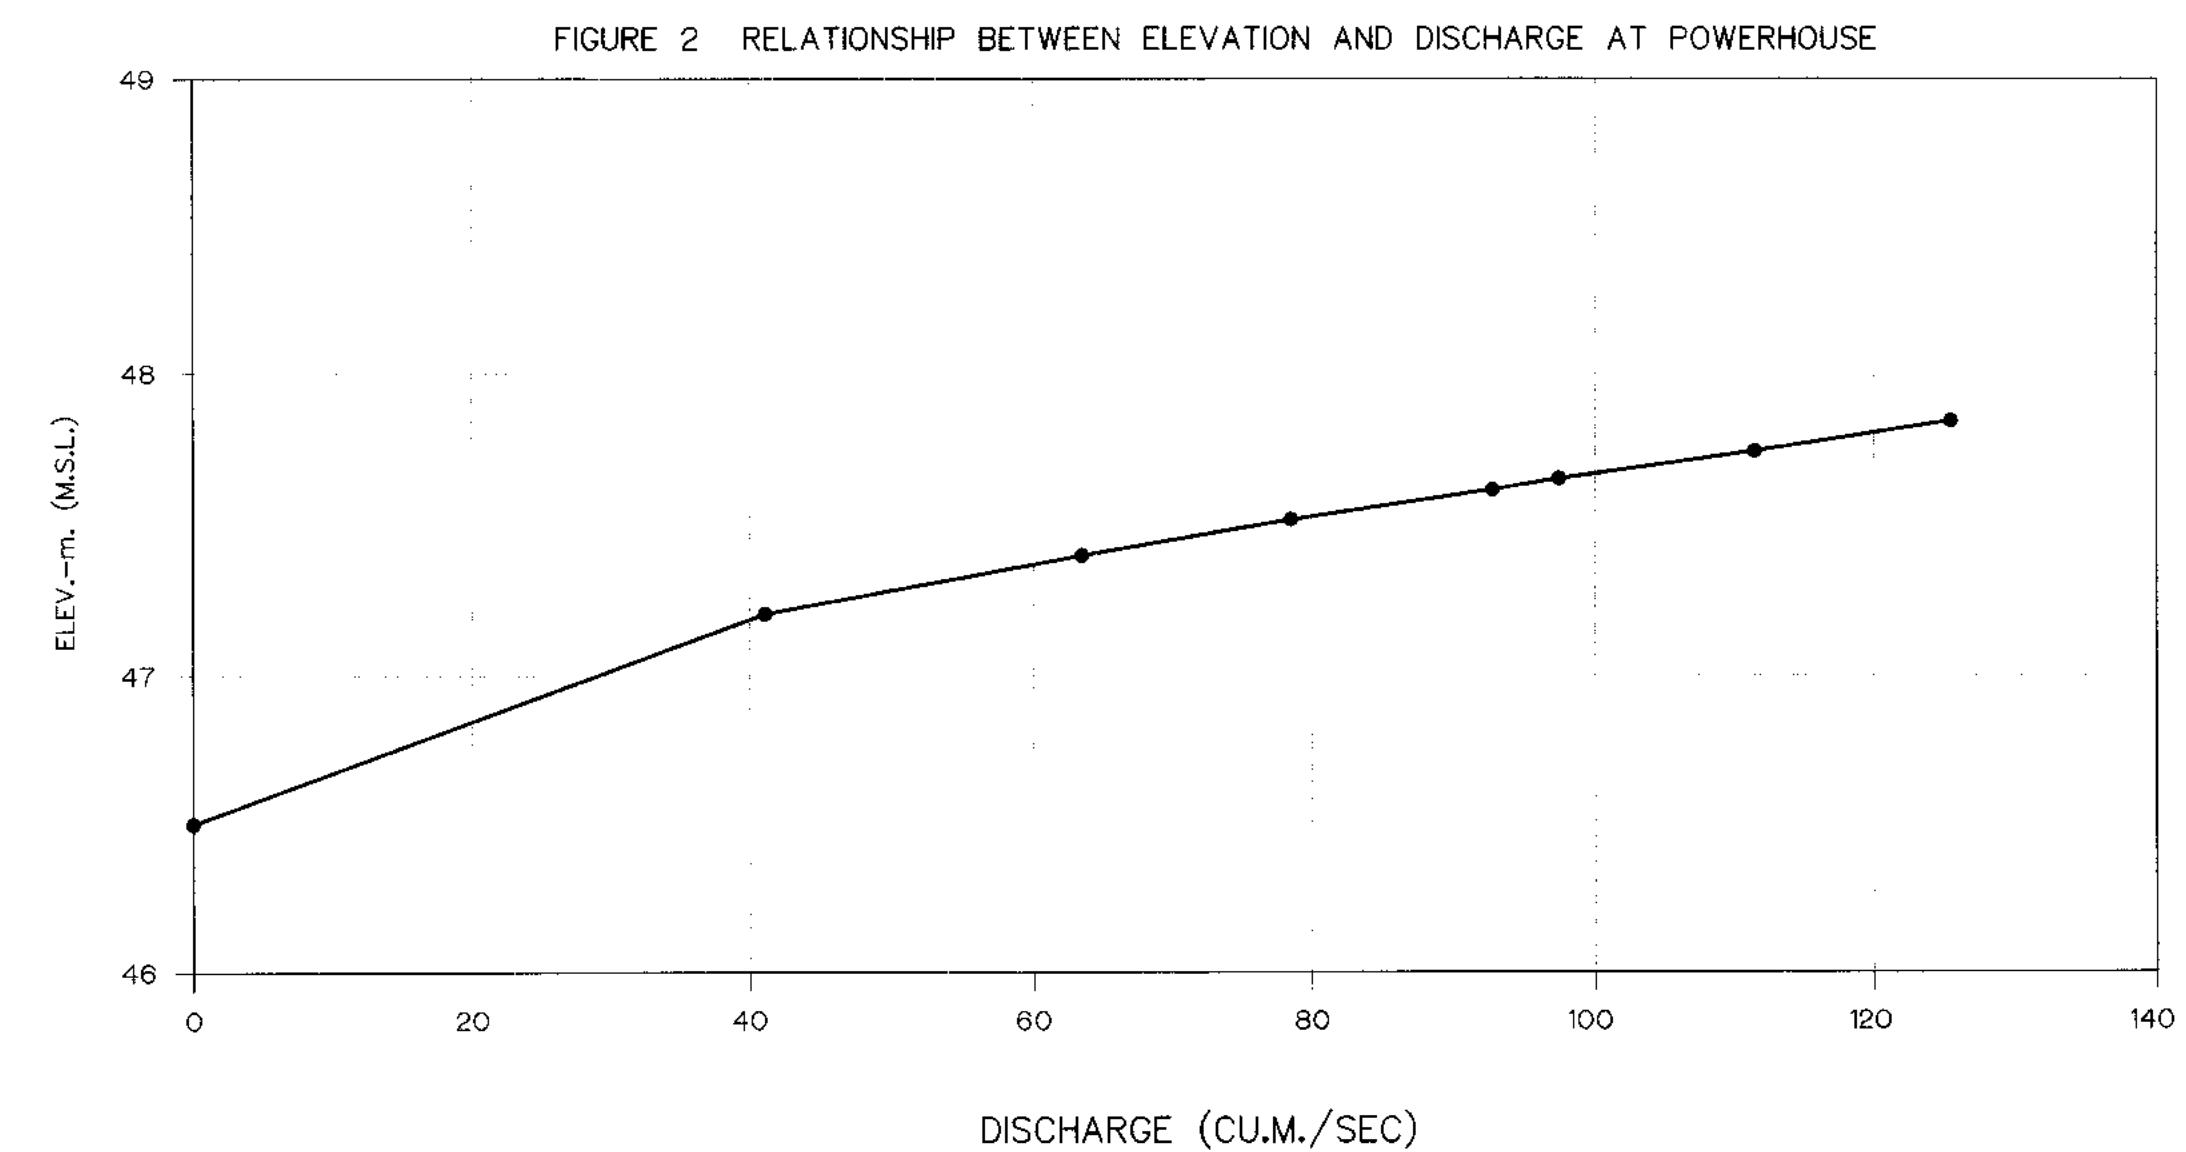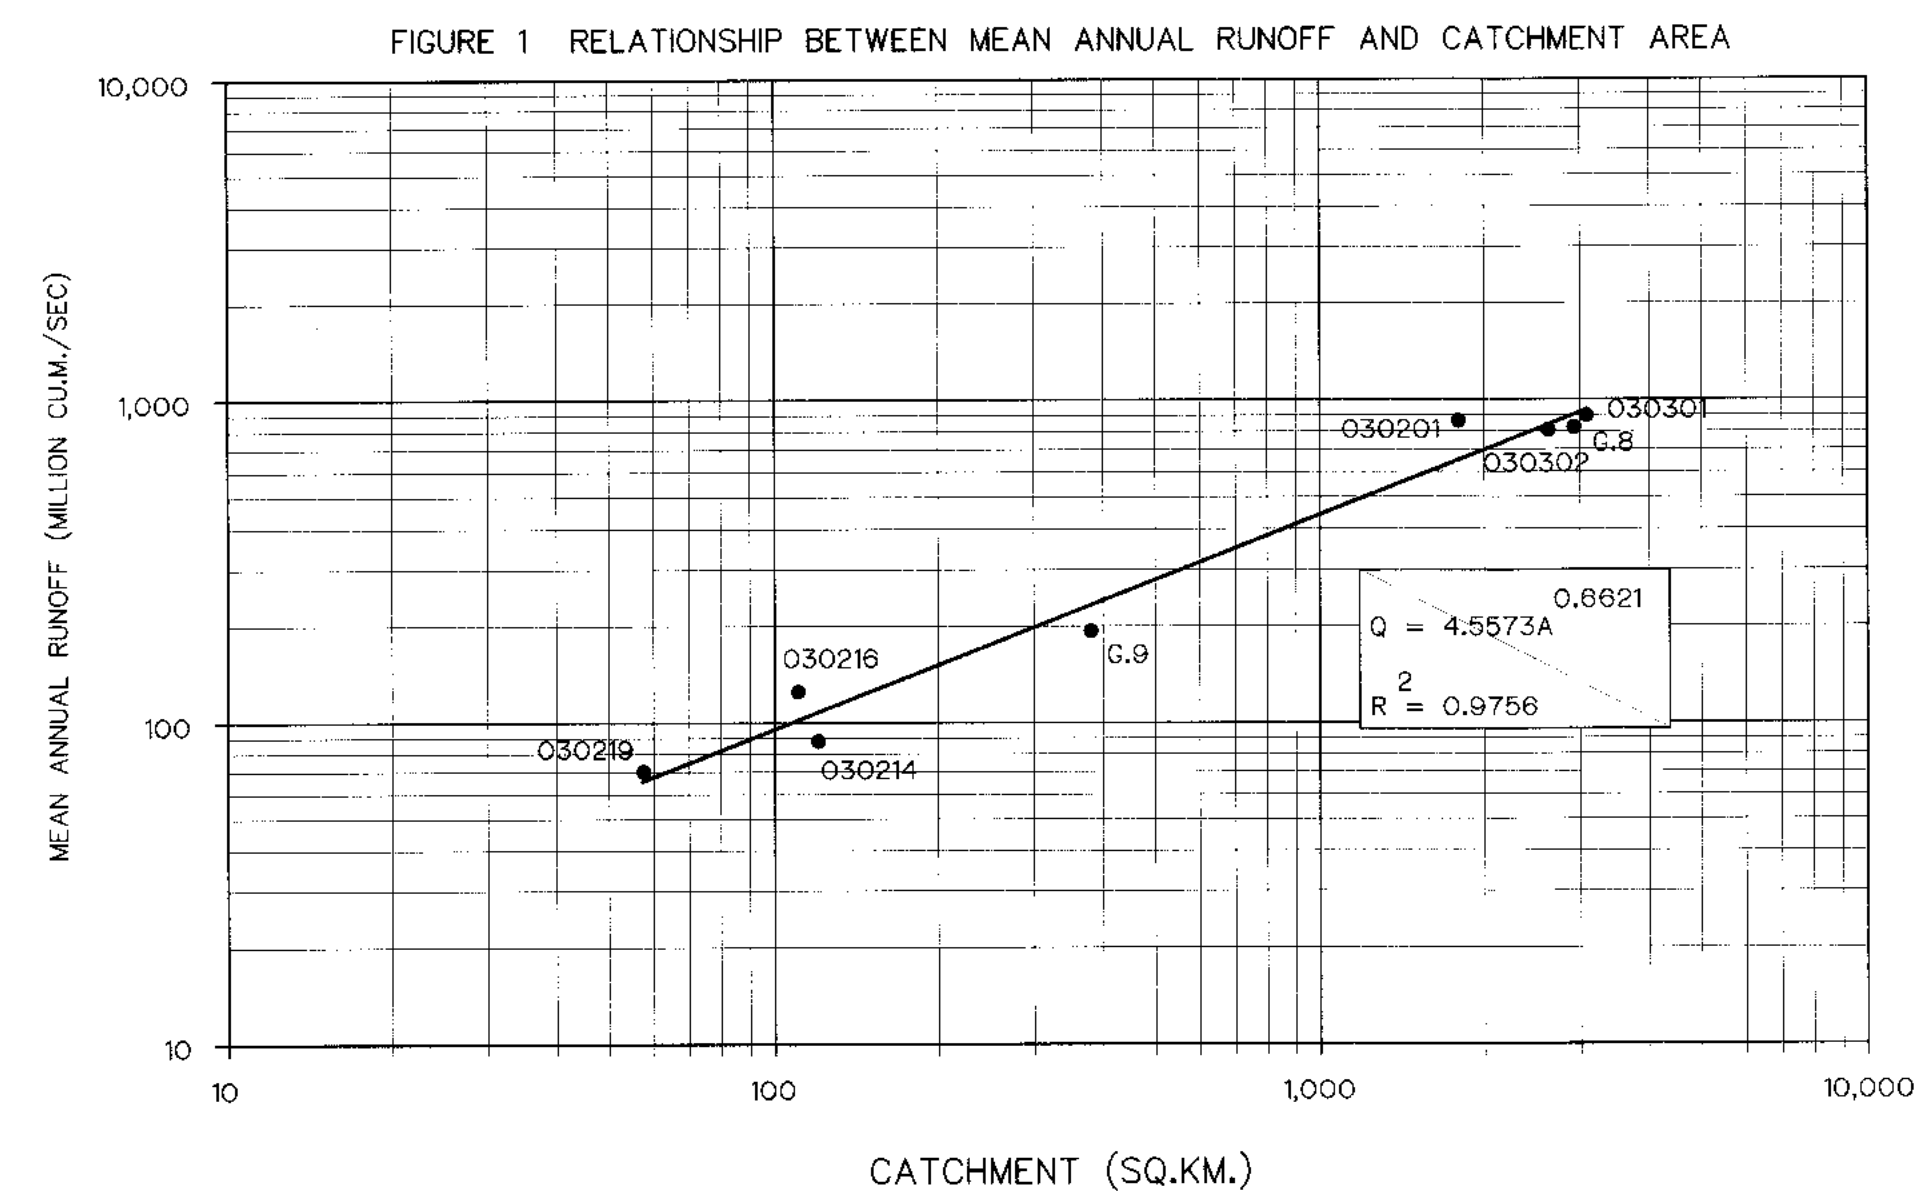

3				
2				
1				
NO.	DATE	REVISIONS	CHECKED	APPROVED
		CONSULTANTS		DEDE

KINGDOM OF THAILAND Department of Alternative Energy Development and Efficiency MINISTRY OF ENERGY	
KLONG LAM PLOK HYDROPOWER PROJECT	
CIVIL WORKS AND TRANSMISSION LINE	
GENERAL DRAWING	
PROJECT INFORMATION HYDROLOGY DATA	
P&C MANAGEMENT CO.,LTD. DESIGNED <i>[Signature]</i> 281.29074 DRAWN <i>[Signature]</i> CHECKED <i>[Signature]</i> 281.0226 PROJECT MANAGER	DEPARTMENT OF ALTERNATIVE ENERGY DEVELOPMENT AND EFFICIENCY MINISTRY OF ENERGY REVIEWED <i>[Signature]</i> SUBMITTED <i>[Signature]</i> RECOMMENDED <i>[Signature]</i> APPROVED <i>[Signature]</i> 281.0226 DATE 08/03/2559
DRAWING NO. KLP-GN-04	SHEET NO. 4 OF 110

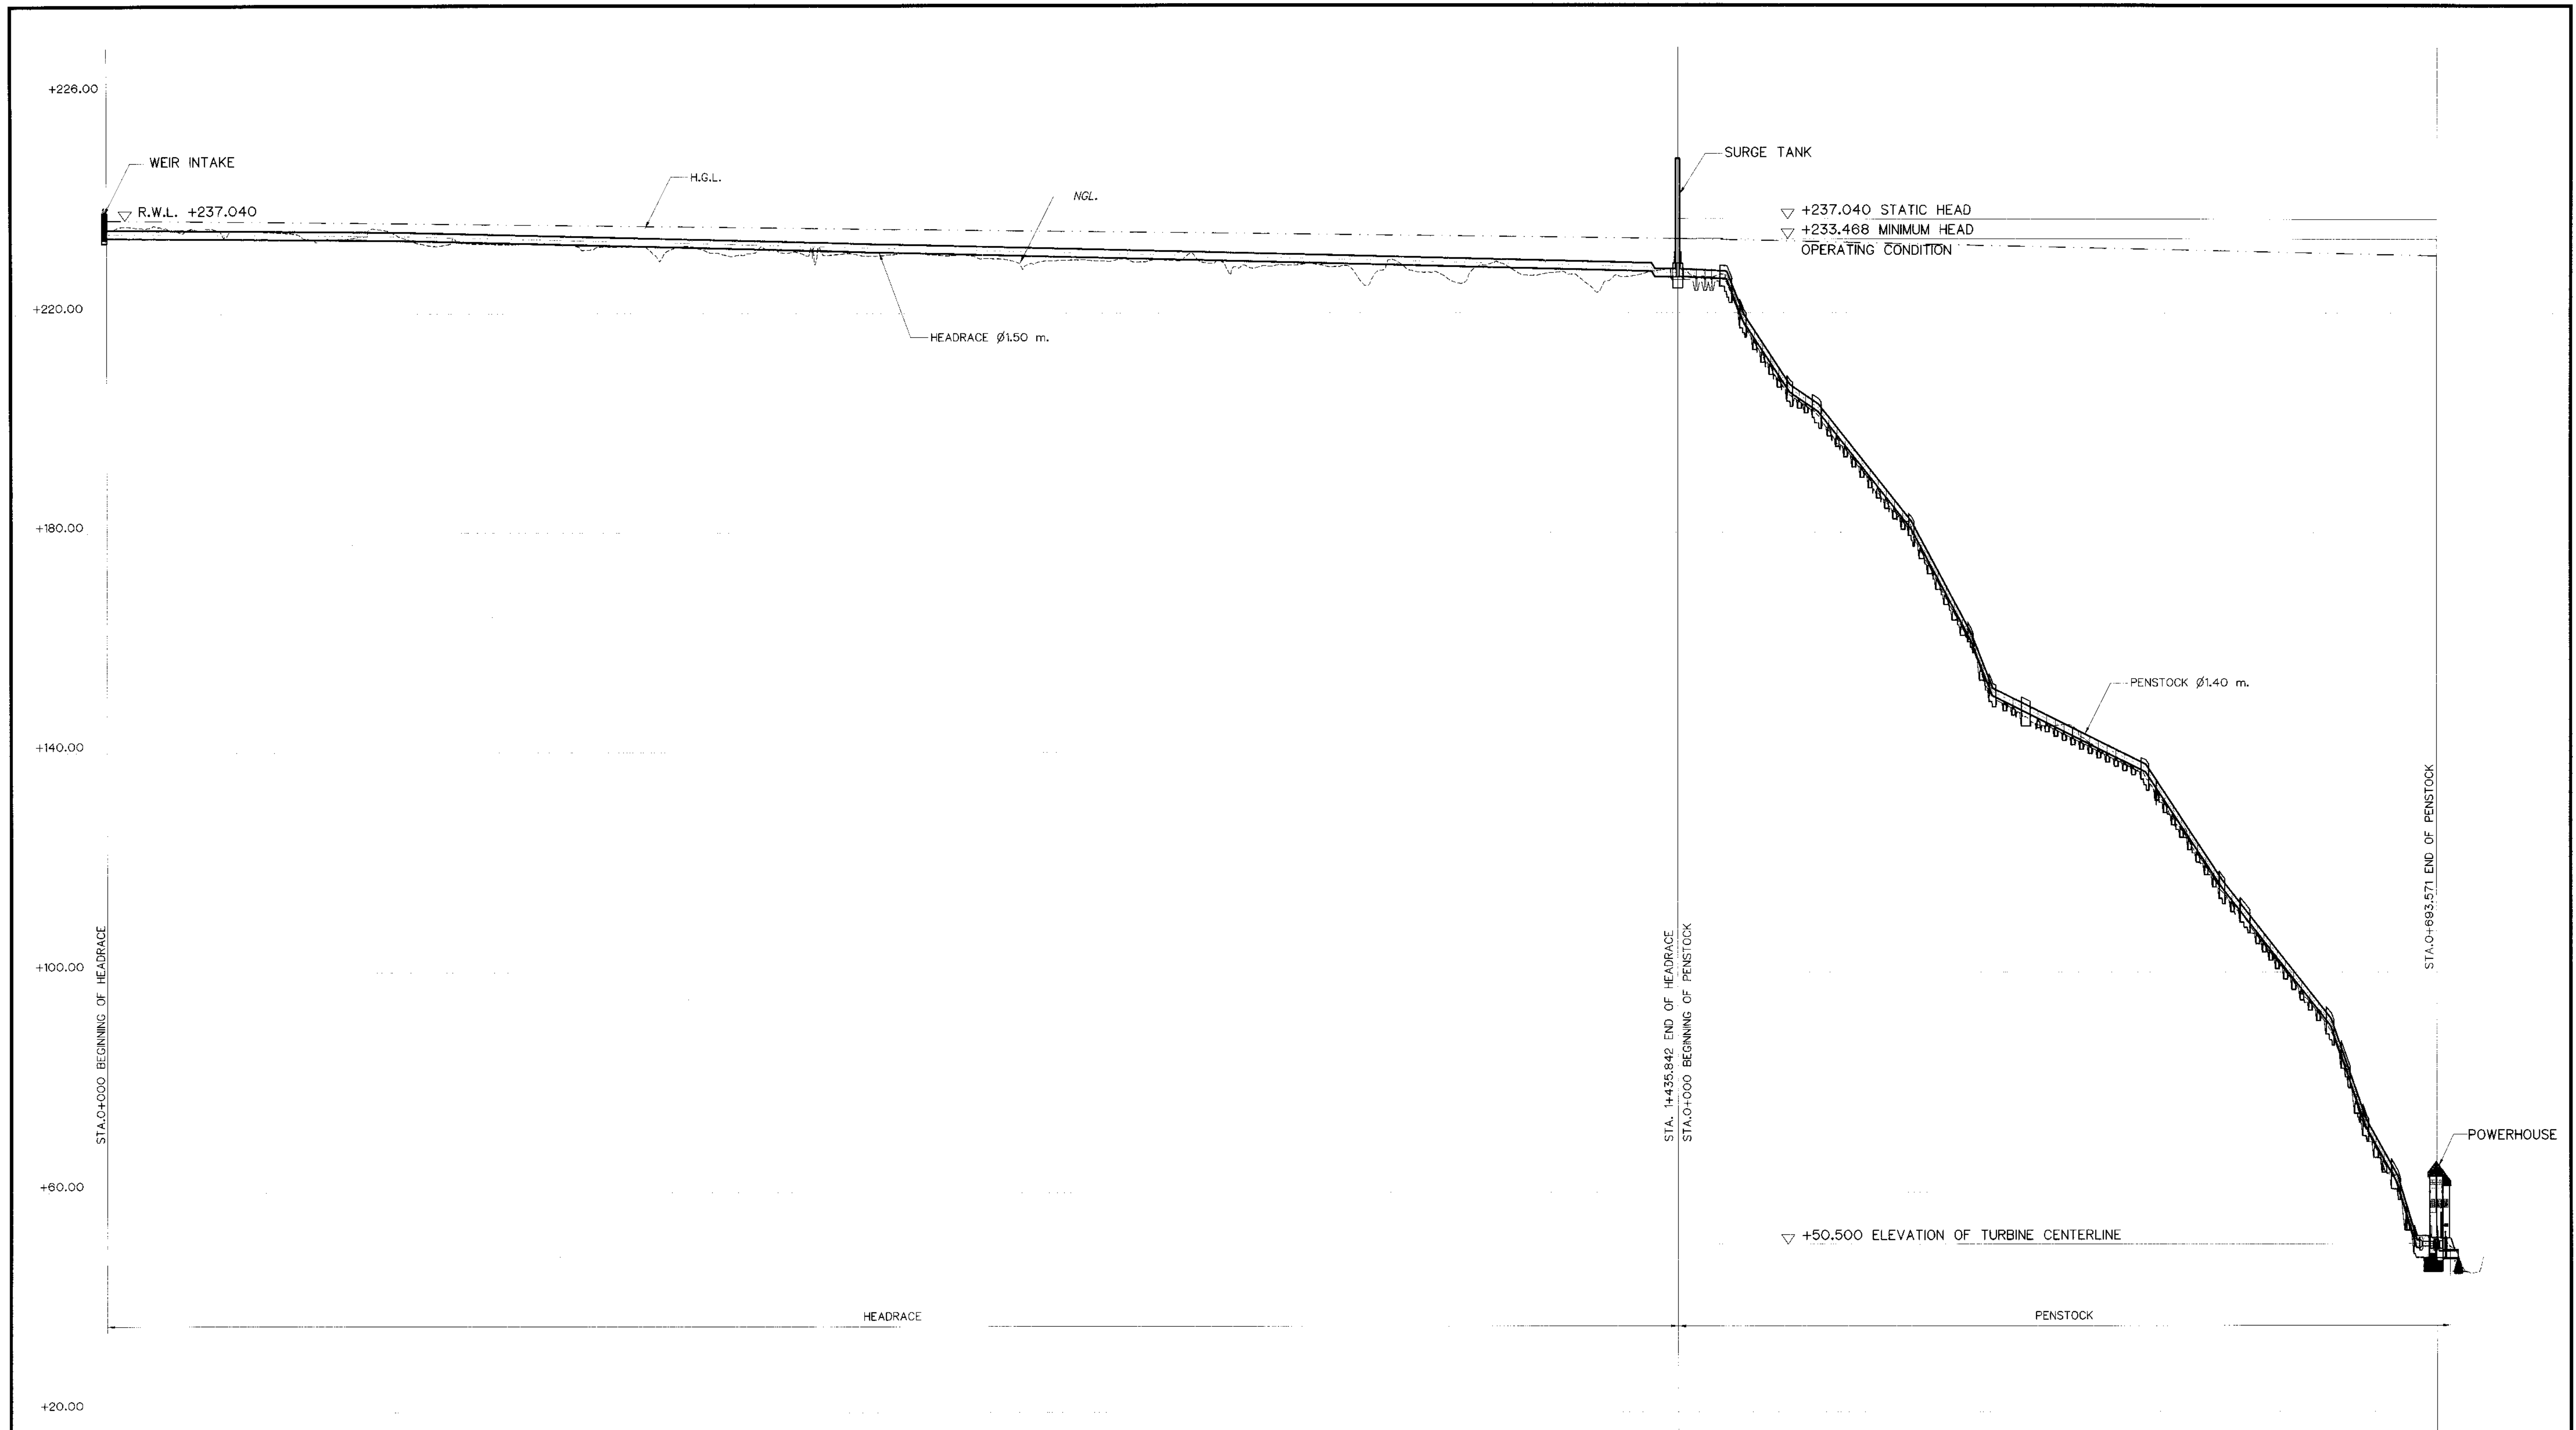


PROFILE ALONG HEADRACE ๑

VERTICAL SCALE 1:800
HORIZONTAL SCALE 1:3,000

NOTES :

1. ALL DIMENSIONS AND ELEVATIONS (M.S.L.) ARE IN METERS, UNLESS OTHERWISE SHOWN.

2. SYMBOLS, ABBREVIATIONS AND GENERAL NOTES SEE DWG. NO. KLP-GN-03

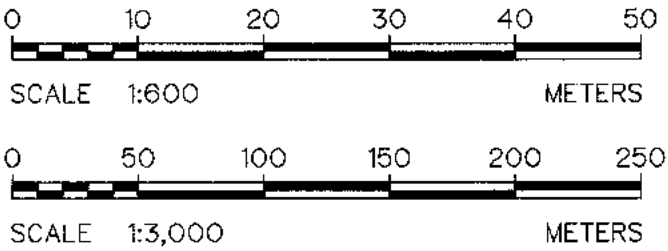


3				
2				
1				
NO.	DATE	REVISIONS	CHECKED	APPROVED

KINGDOM OF THAILAND
Department of Alternative
Energy Development and Efficiency
MINISTRY OF ENERGY

KLONG LAM PLOK HYDROPOWER PROJECT

CIVIL WORKS AND TRANSMISSION LINE
GENERAL DRAWING
POWER WATERWAY HYDRAULIC ARRANGEMENT


P&C MANAGEMENT CO.,LTD.	REVIEWED
DESIGNED <i>[Signature]</i> JML/28074 B.V. 28.8226	SUBMITTED <i>[Signature]</i>
DRAWN <i>[Signature]</i>	RECOMMENDED <i>[Signature]</i>
CHECKED <i>[Signature]</i> B.V. 28.8226	APPROVED <i>[Signature]</i> P. Harnsri
<i>[Signature]</i> PROJECT MANAGER 08/03/2559 DATE	DRAWING NO. KLP-GN-05 SHEET NO. 5 OF 110

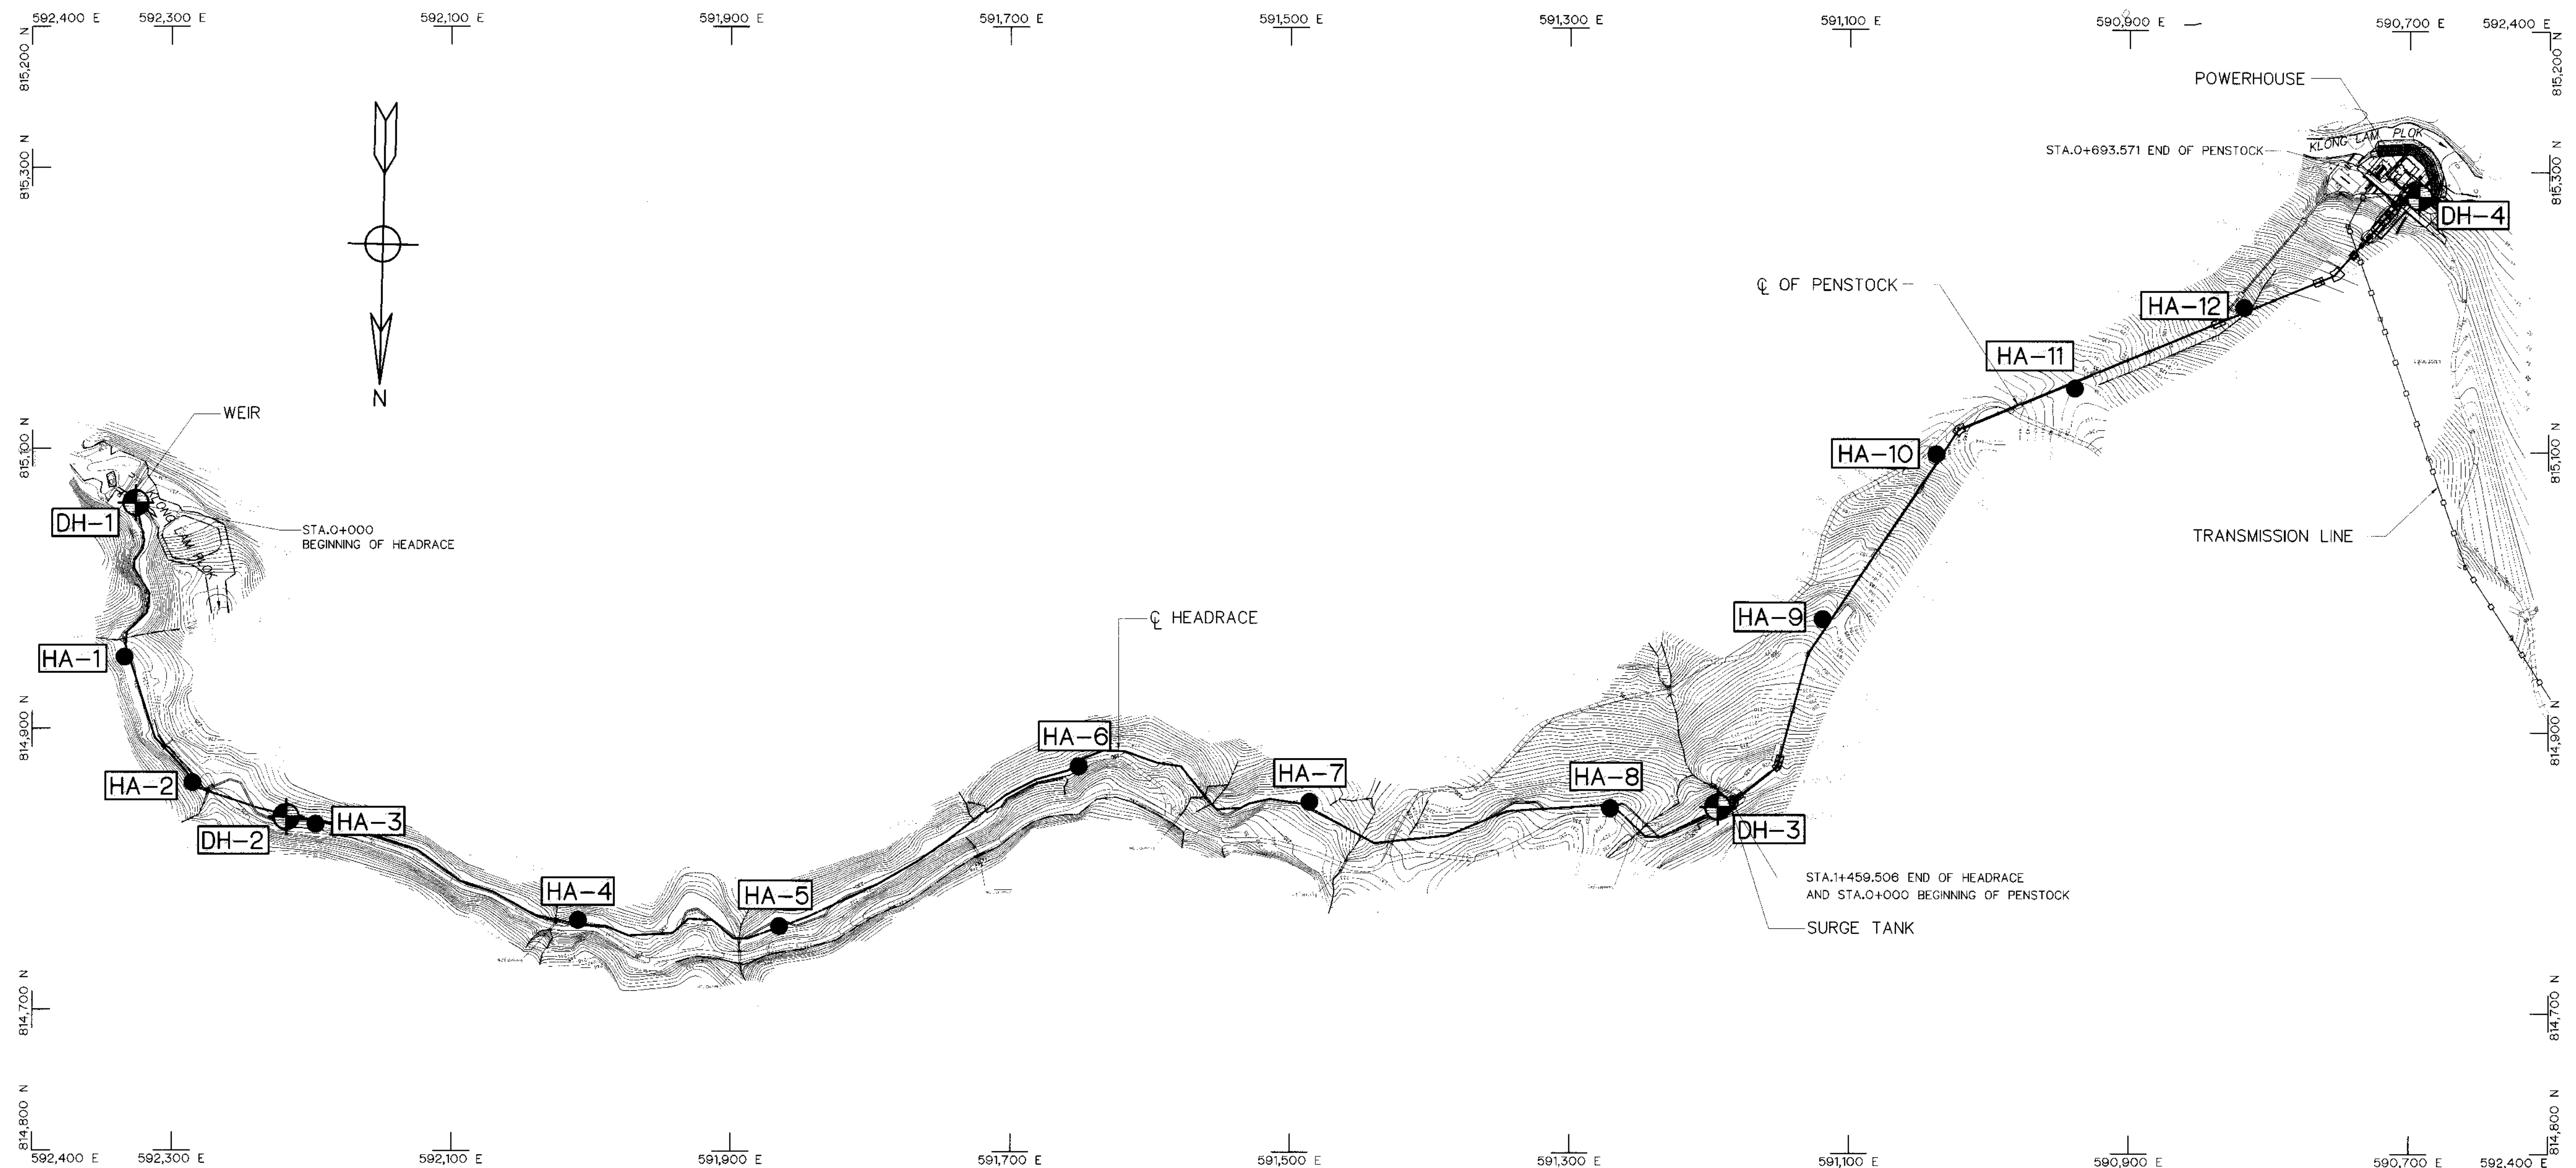

PROJECT LAYOUT
SCALE 1:2,500



NOTES :

1. ALL DIMENSIONS AND ELEVATIONS (M.S.L.) ARE IN METERS, UNLESS OTHERWISE SHOWN.
2. SYMBOLS, ABBREVIATIONS AND GENERAL NOTES SEE DWG. NO. KLP-GN-03

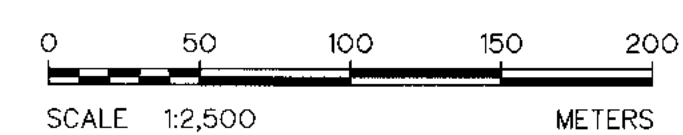


3				
2				
1				
NO.	DATE	REVISIONS	CHECKED	APPROVED
		CONSULTANTS		DEDE


 KINGDOM OF THAILAND Department of Alternative Energy Development and Efficiency MINISTRY OF ENERGY			
KLONG LAM PLOK HYDROPOWER PROJECT			
CIVIL WORKS AND TRANSMISSION LINE GENERAL DRAWING GEOLOGICAL, PLAN			
 P&C MANAGEMENT CO.,LTD.		 Department of Alternative Energy Development and Efficiency MINISTRY OF ENERGY	
DESIGNED  28.29074 28.6226		REVIEWED 	
DRAWN 		SUBMITTED 	
CHECKED  28.6226		RECOMMENDED 	
APPROVED 		APPROVED 	
PROJECT MANAGER  08/03/2559		DRAWING NO. KLP-GN-06	
DATE		SHEET NO. 6 OF 110	

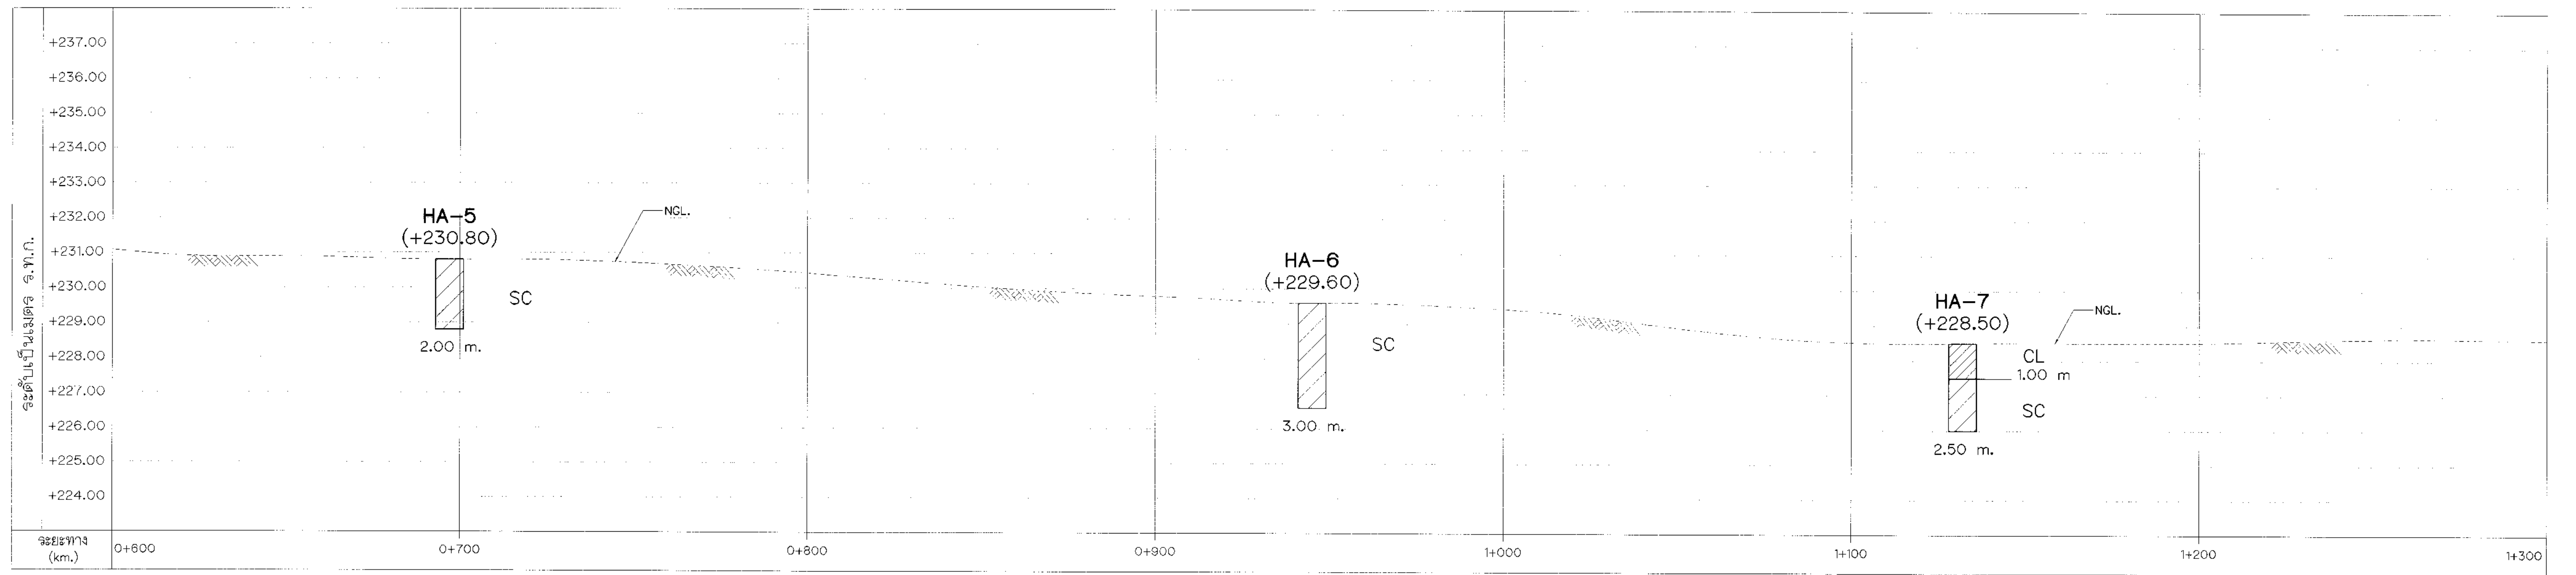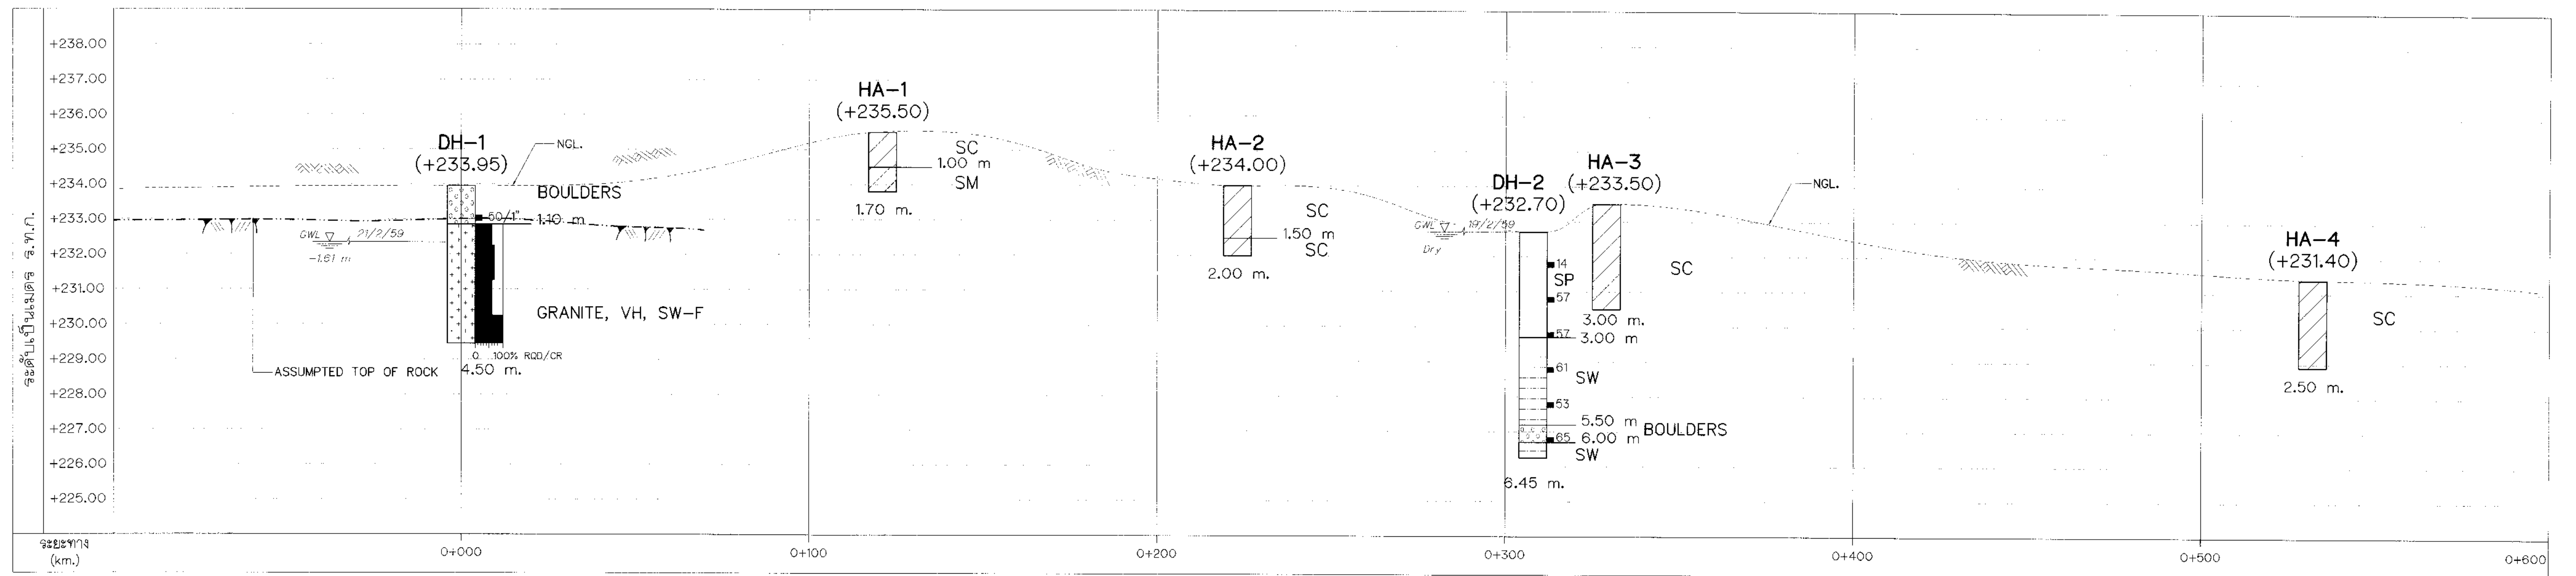

Explanation

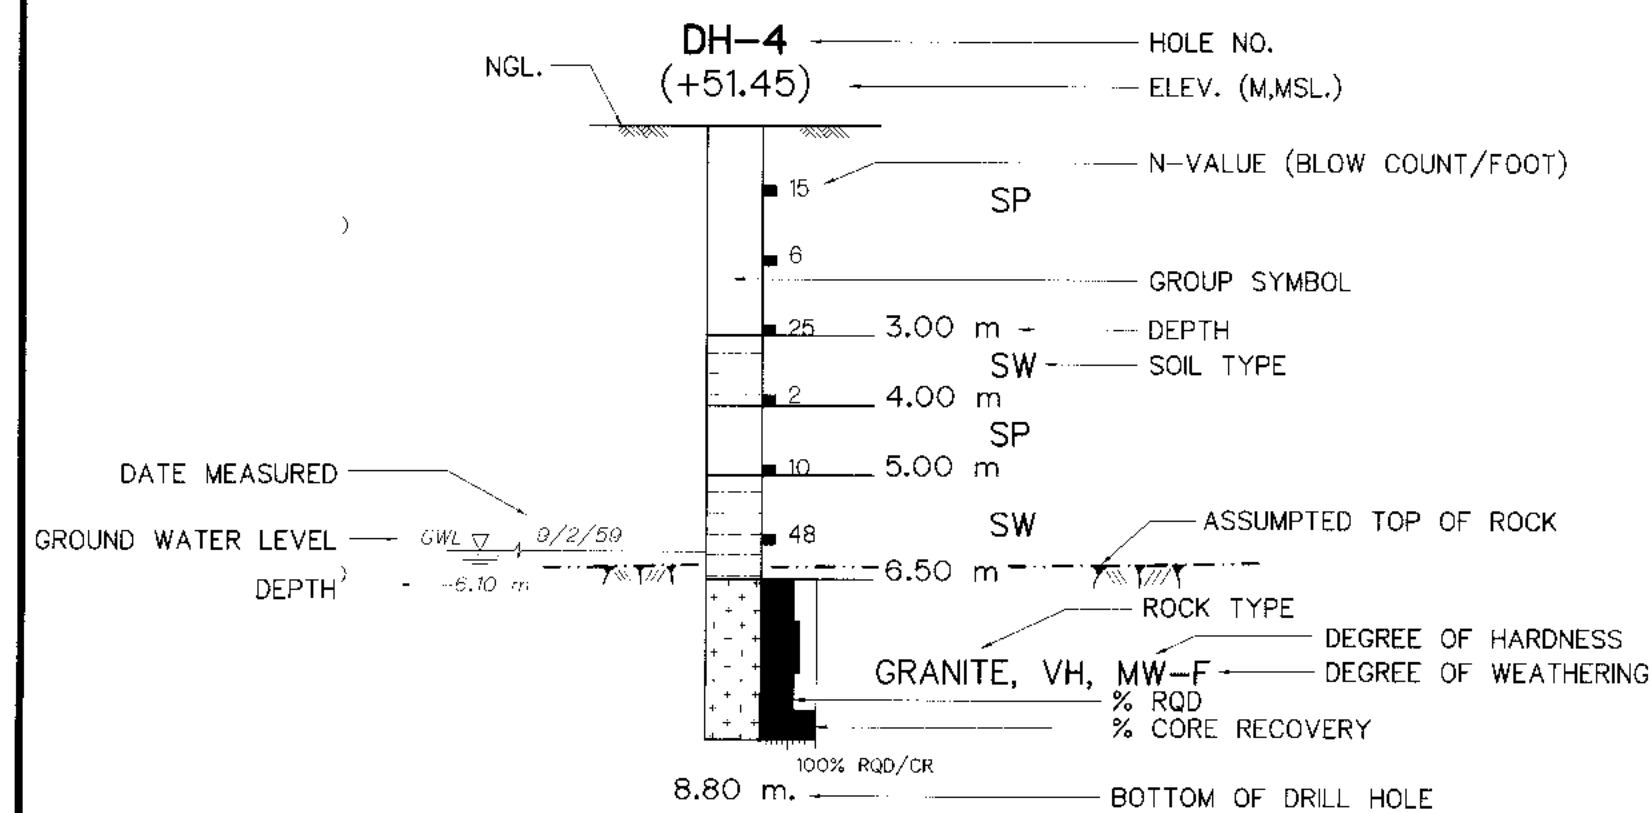

Legend

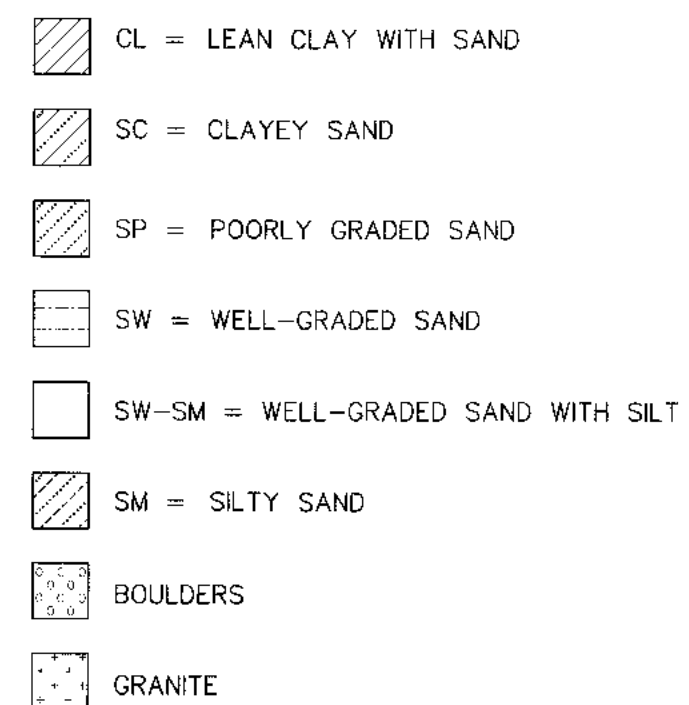

DEGREE OF WEATHERING

F = FRESH ROCK
SW = SLIGHTLY WEATHERED ROCK
MW = MODERATELY WEATHERED ROCK
HW = HIGHLY WEATHERED ROCK
CW = COMPLETELY WEATHERED ROCK

DEGREE OF HARDNESS



VS = VERY SOFT ROCK
S = SOFT ROCK
MH = MEDIUM HARD ROCK
H = HARD ROCK
VH = VERY HARD ROCK

% RQD

< 25% = VERY POOR ROCK
25-50% = POOR ROCK
50-75% = FAIR ROCK
75-90% = GOOD ROCK
90-100% = VERY GOOD ROCK

DEGREE OF PERMEABILITY


1 = < 1 LUG EON OR < 10⁻⁵ CM/SEC = IMPERVIOUS
2 = 1-5 LUG EON OR 10⁻⁵ - 5x10⁻⁵ CM/SEC = SEMI - IMPERVIOUS
3 = 5-10 LUG EON OR 5x10⁻⁵ - 10⁻⁴ CM/SEC = SEMI - PERVIOUS
4 = 10-50 LUG EON OR 10⁻⁴ - 5x10⁻⁴ CM/SEC = RATHER - PERVIOUS
5 = > 50 LUG EON OR > 5x10⁻⁴ CM/SEC = PERVIOUS

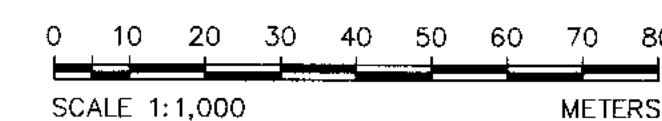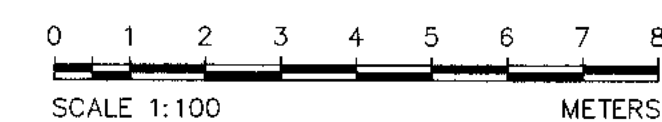

3				
2				
1				
NO.	DATE	REVISIONS	CHECKED	APPROVED


KINGDOM OF THAILAND Department of Alternative Energy Development and Efficiency MINISTRY OF ENERGY	
KLONG LAM PLOK HYDROPOWER PROJECT	
CIVIL WORKS AND TRANSMISSION LINE GENERAL DRAWING GEOLOGICAL, PROFILE (SHEET 1/3)	
P&C MANAGEMENT CO.,LTD. DESIGNED: 28.29074 DRAWN: 28.6226 CHECKED: 28.6226 PROJECT MANAGER: 08/03/2559	REVIEWED: 28.6226 SUBMITTED: 28.6226 RECOMMENDED: 28.6226 APPROVED: 28.6226 DRAWING NO. KLP-GN-07 SHEET NO. 7 OF 110

 KINGDOM OF THAILAND Department of Alternative Energy Development and Efficiency MINISTRY OF ENERGY	
KLONG LAM PLOK HYDROPOWER PROJECT	
CIVIL WORKS AND TRANSMISSION LINE GENERAL DRAWING GEOLOGICAL, PROFILE (SHEET 3/3)	
 P&C MANAGEMENT CO.,LTD.	 Department of Alternative Energy Development and Efficiency MINISTRY OF ENERGY
DESIGNED <i>Wu #12.29074</i> <i>074</i> <i>081.9226</i>	REVIEWED <i>Wu</i>
DRAWN <i>grom</i> <i>074</i>	SUBMITTED <i>Chant</i>
CHECKED <i>074</i> <i>081.9226</i>	RECOMMENDED <i>074</i> <i>081.9226</i>
PROJECT MANAGER <i>074</i>	DRAWING NO. <i>074</i>
DATE	SHEET NO. <i>9 OF 110</i>

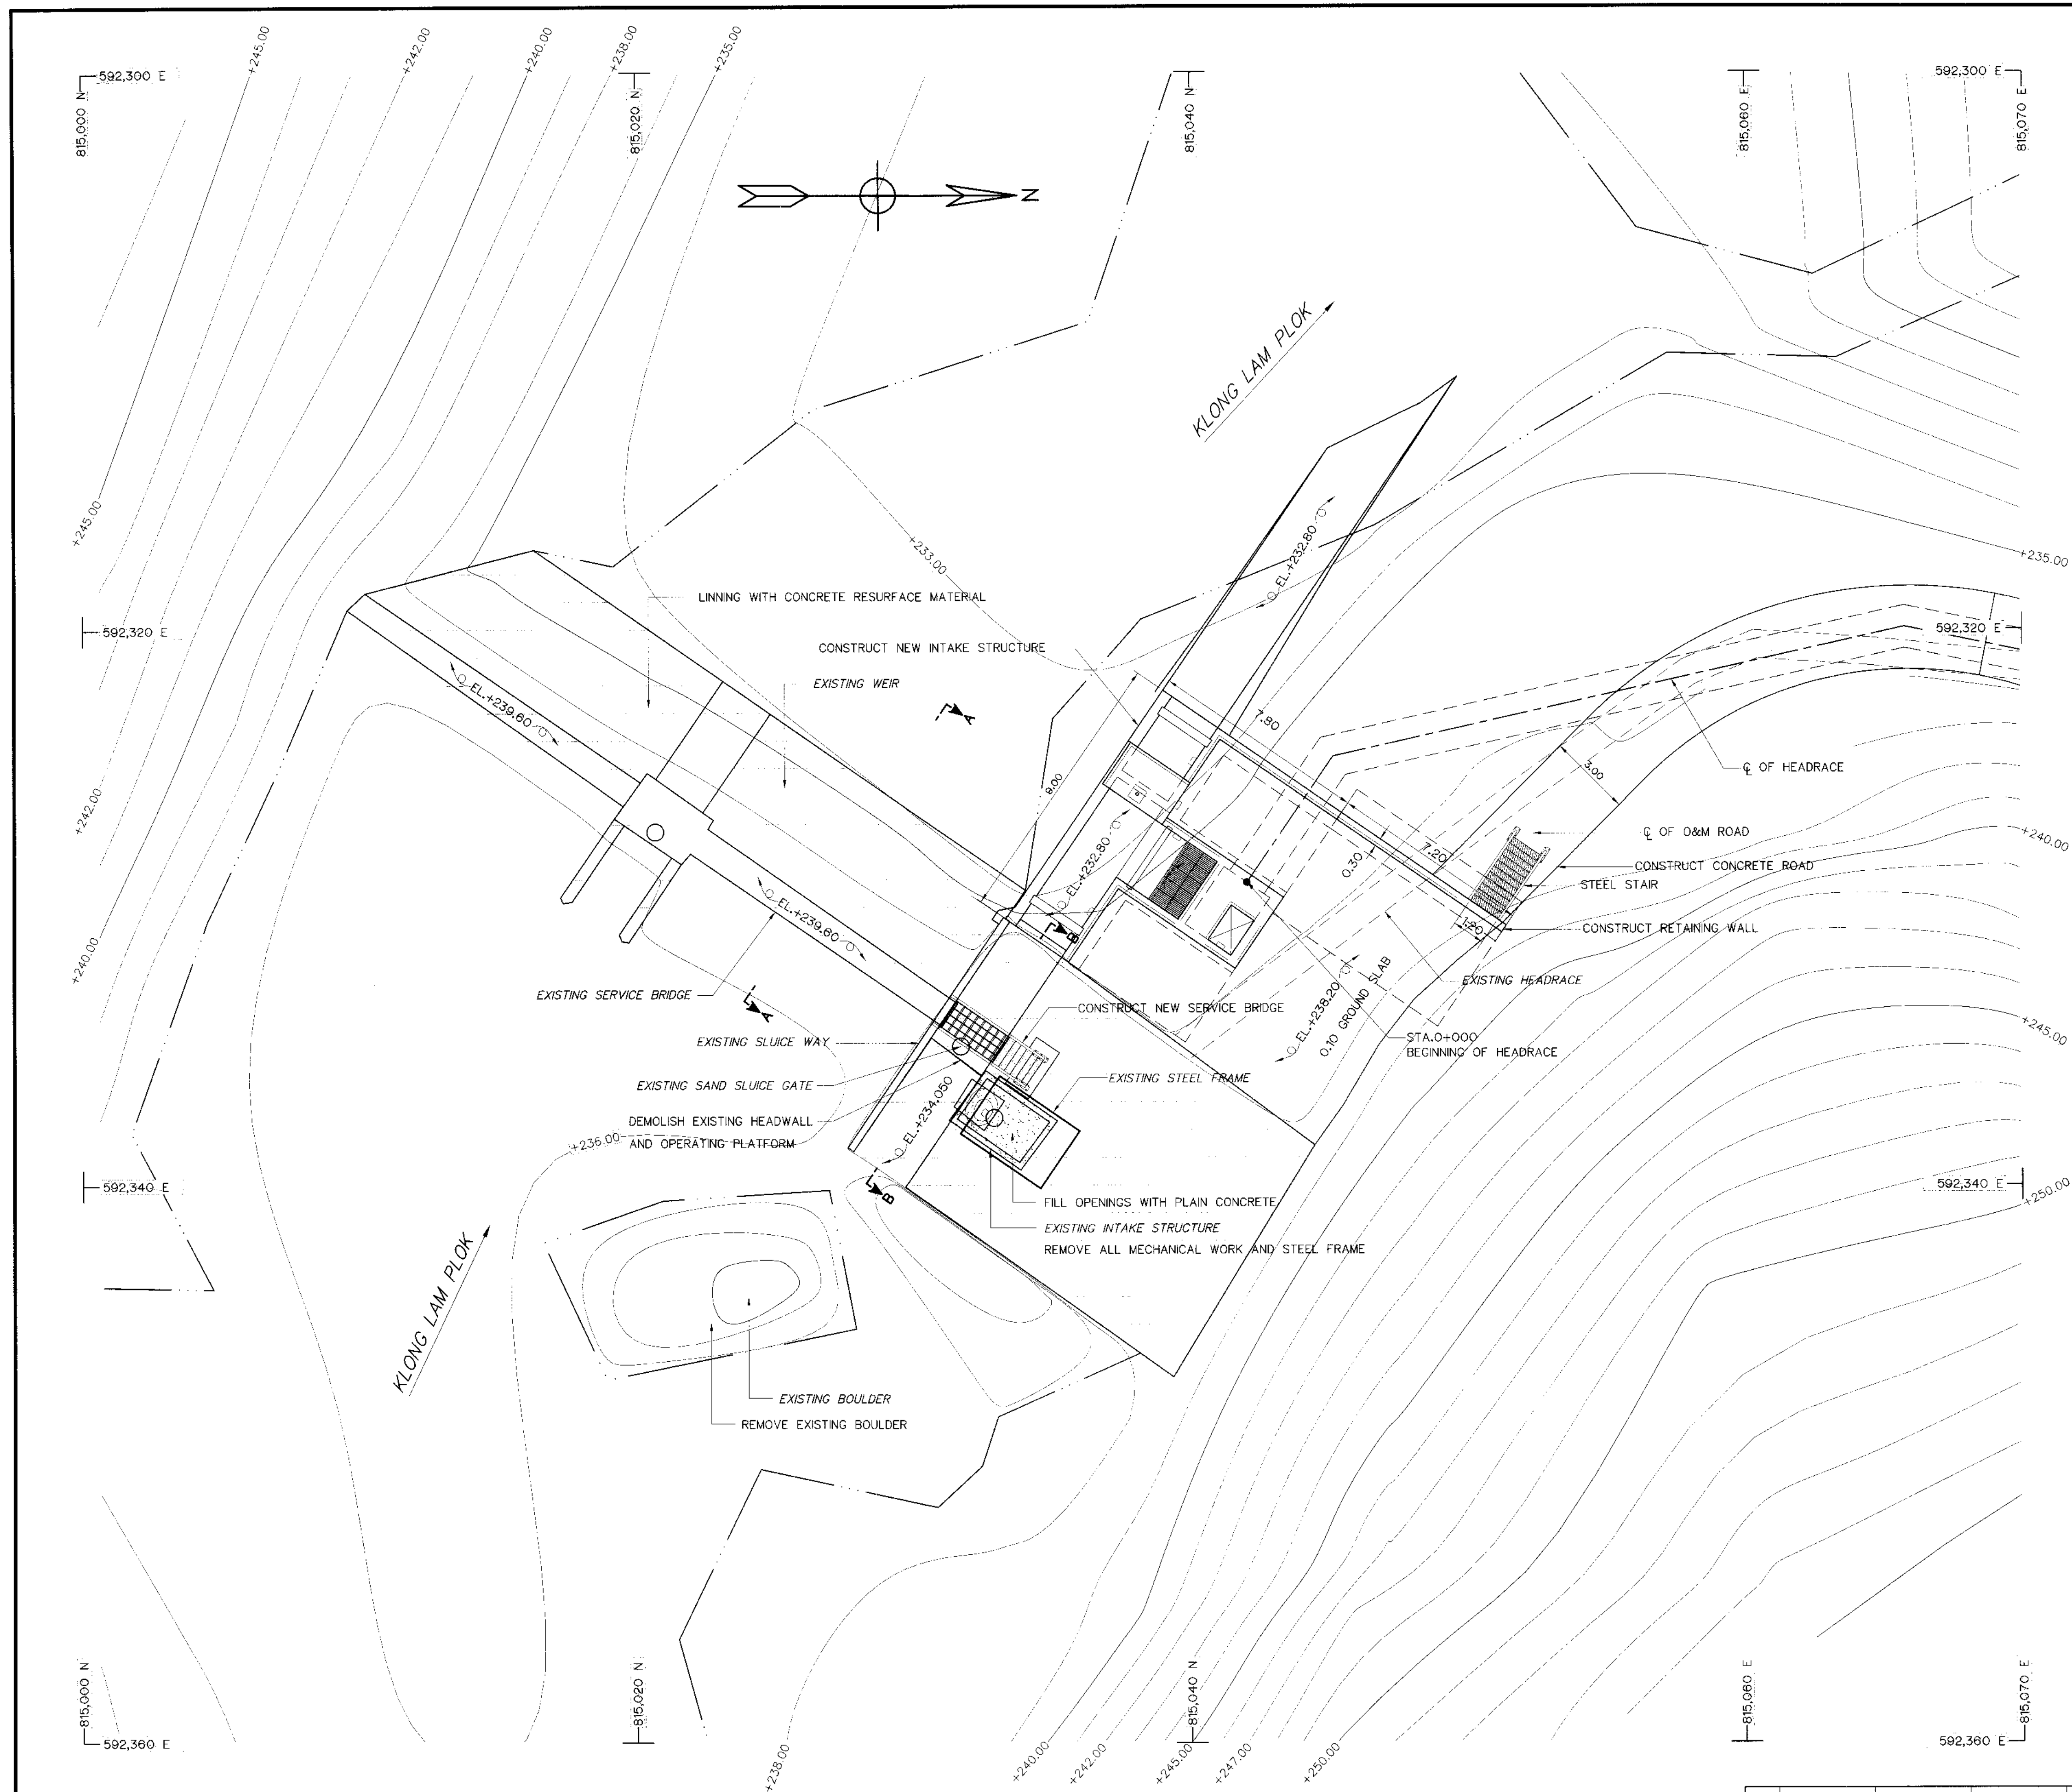

GENERAL LAY-OUT
SCALE 1:125

 LEGEND :


 EXISTING STRUCTURE

NOTES :

1. ALL DIMENSIONS AND ELEVATIONS (M.S.L.) ARE IN METERS, UNLESS OTHERWISE SHOWN.
2. SYMBOLS, ABBREVIATIONS AND GENERAL NOTES SEE DWG. NO. KLP-GN-03
3. INTAKE STRUCTURE SHALL BE PLACED ON BED ROCK FOUNDATION, OTHER MATERIALS SHALL BE REMOVED AND BACKFILLED WITH LEAN CONCRETE AND THE LEAN CONCRETE SHALL HAVE THE COMPRESSIVE STRENGTH OF 140 KSC. FOR STANDARD CYLINDER AT 28 DAYS.
4. ALLOWABLE BEARING CAPACITY NOT LESS THAN 15 TON/sq m.


REFERENCE DRAWINGS :

- | | |
|---|-----------|
| 1. WEIR : WEIR REHABILITATION SECTION AND DETAILS | KLP-WE-02 |
| 2. WEIR : WEIR REHABILITATION SERVICE BRIDGE | KLP-WE-03 |
| 3. WEIR : INTAKE STRUCTURE PLAN AND SECTIONS | KLP-WE-04 |
| 4. WEIR : INTAKE STRUCTURE MISCELLANEOUS DETAILS | KLP-WE-08 |

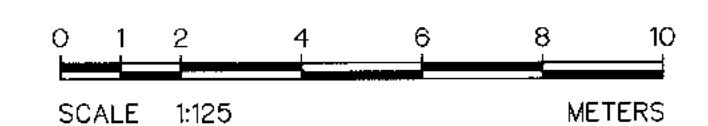


KINGDOM OF THAILAND Department of Alternative Energy Development and Efficiency MINISTRY OF ENERGY	
KLONG LAM PLOK HYDROPOWER PROJECT	
CIVIL WORKS AND TRANSMISSION LINE WEIR : WEIR REHABILITATION GENERAL LAY-OUT	
 P&C MANAGEMENT CO.,LTD.	 DEPARTMENT OF ALTERNATIVE ENERGY DEVELOPMENT AND EFFICIENCY MINISTRY OF ENERGY
DESIGNED <i>Mr. P. 29074</i> <i>01.01.6226</i>	REVIEWED <i>Charat</i>
DRAWN <i>Mr. X</i>	RECOMMENDED <i>Mr. X</i>
CHECKED <i>01.01.6226</i>	APPROVED <i>P. Harnsri</i>
PROJECT MANAGER <i>08/03/2559</i>	DRAWING NO. KLP-WE-01
DATE	SHEET NO. 10 OF 110


NO.	DATE	REVISIONS	CHECKED	APPROVED
3				
2				
1				
CONSULTANTS		DEDE		

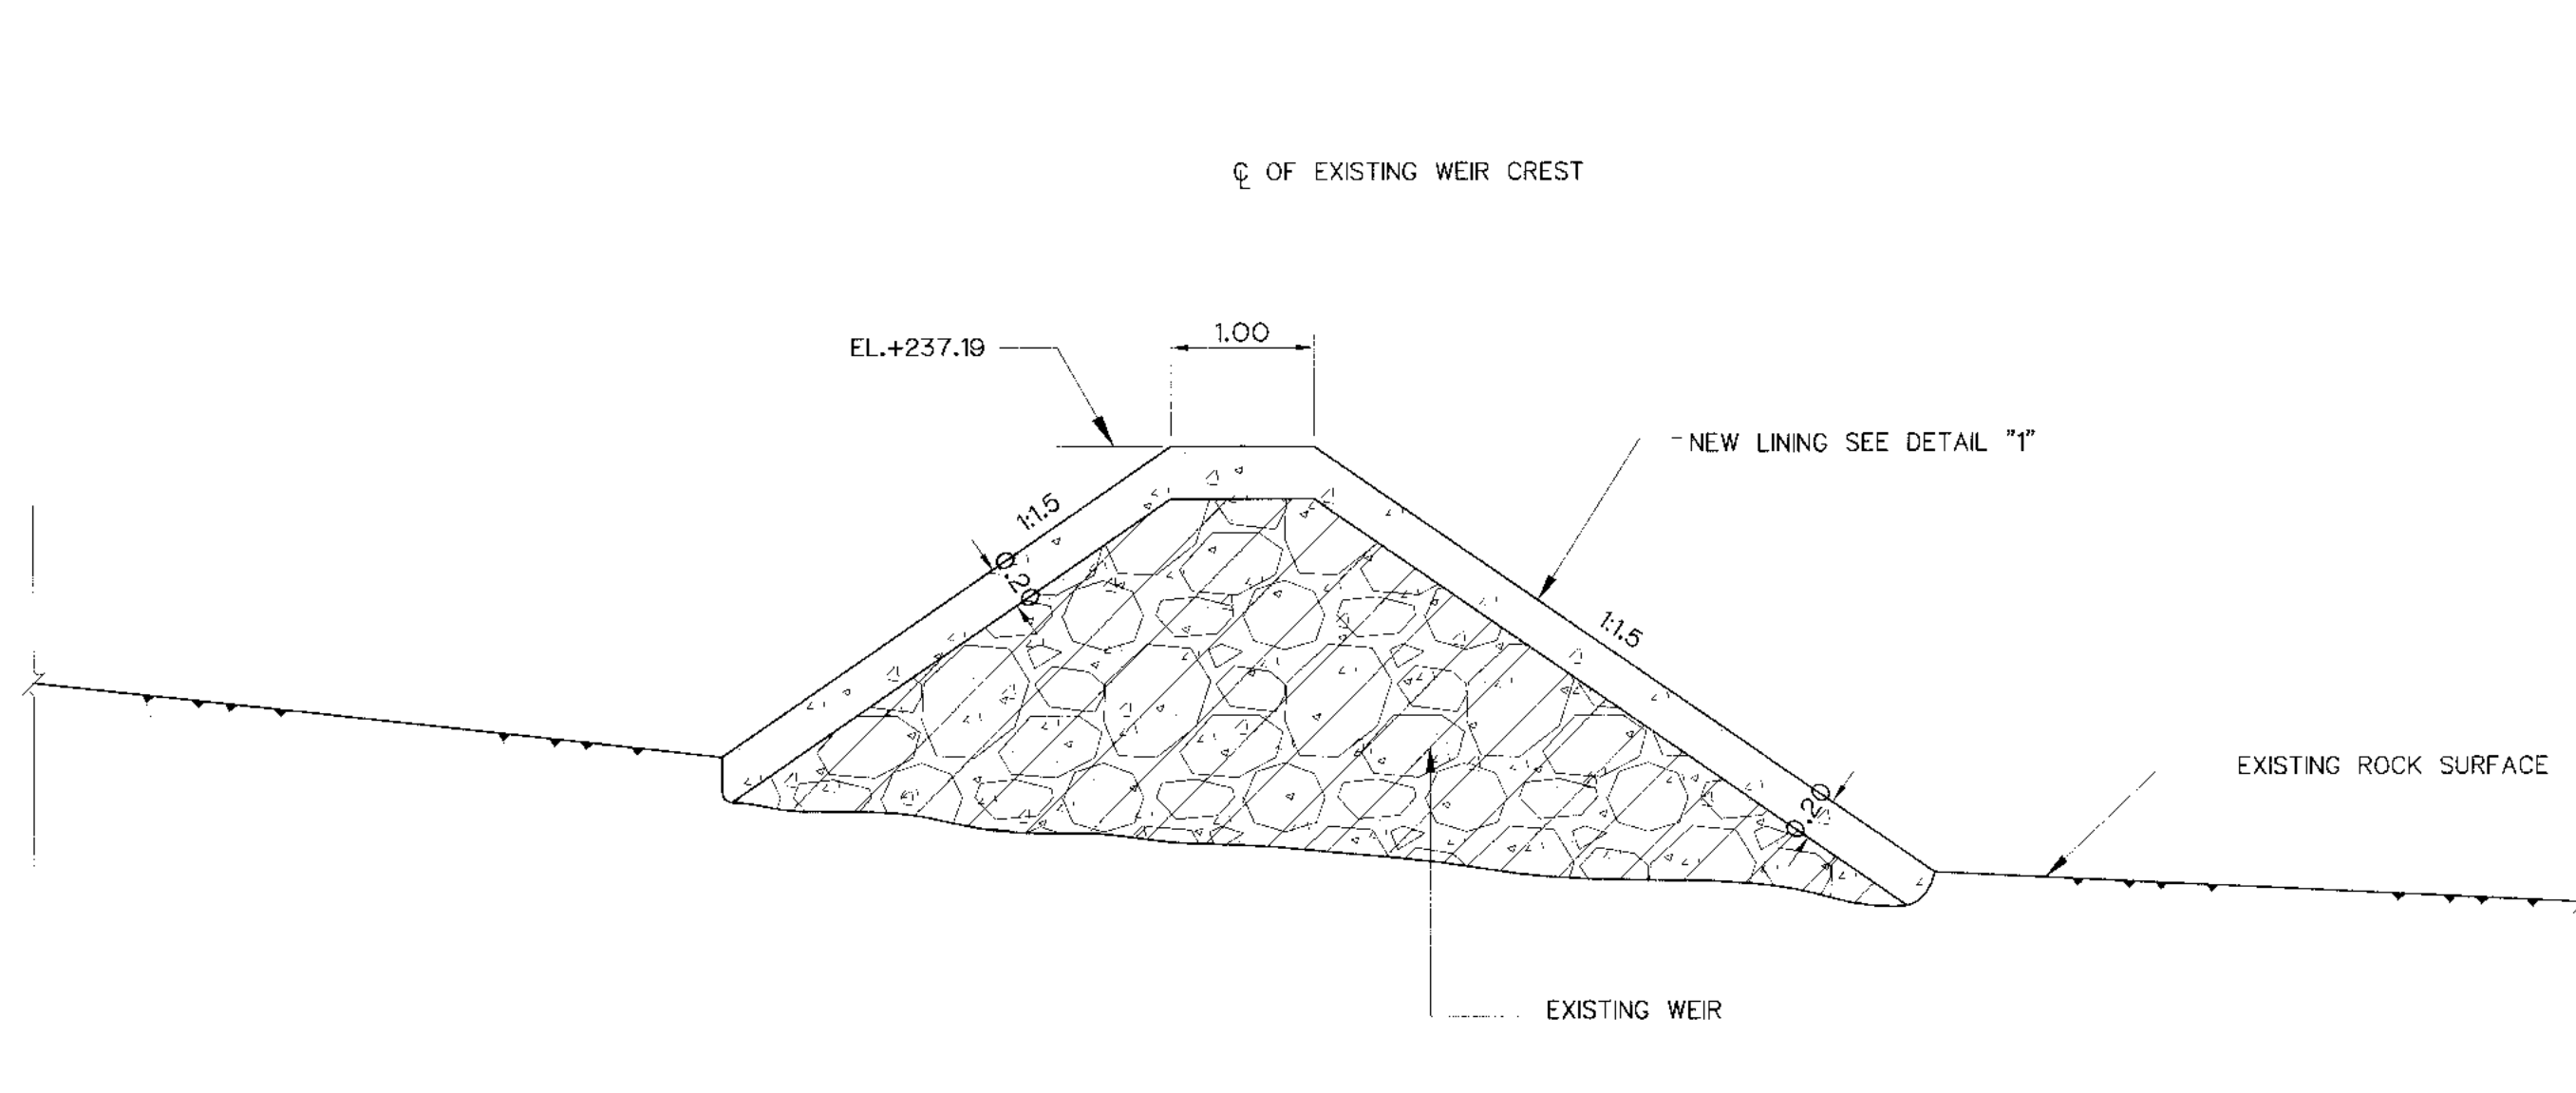

SECTION OF WEIR A-A
SCALE 1:50

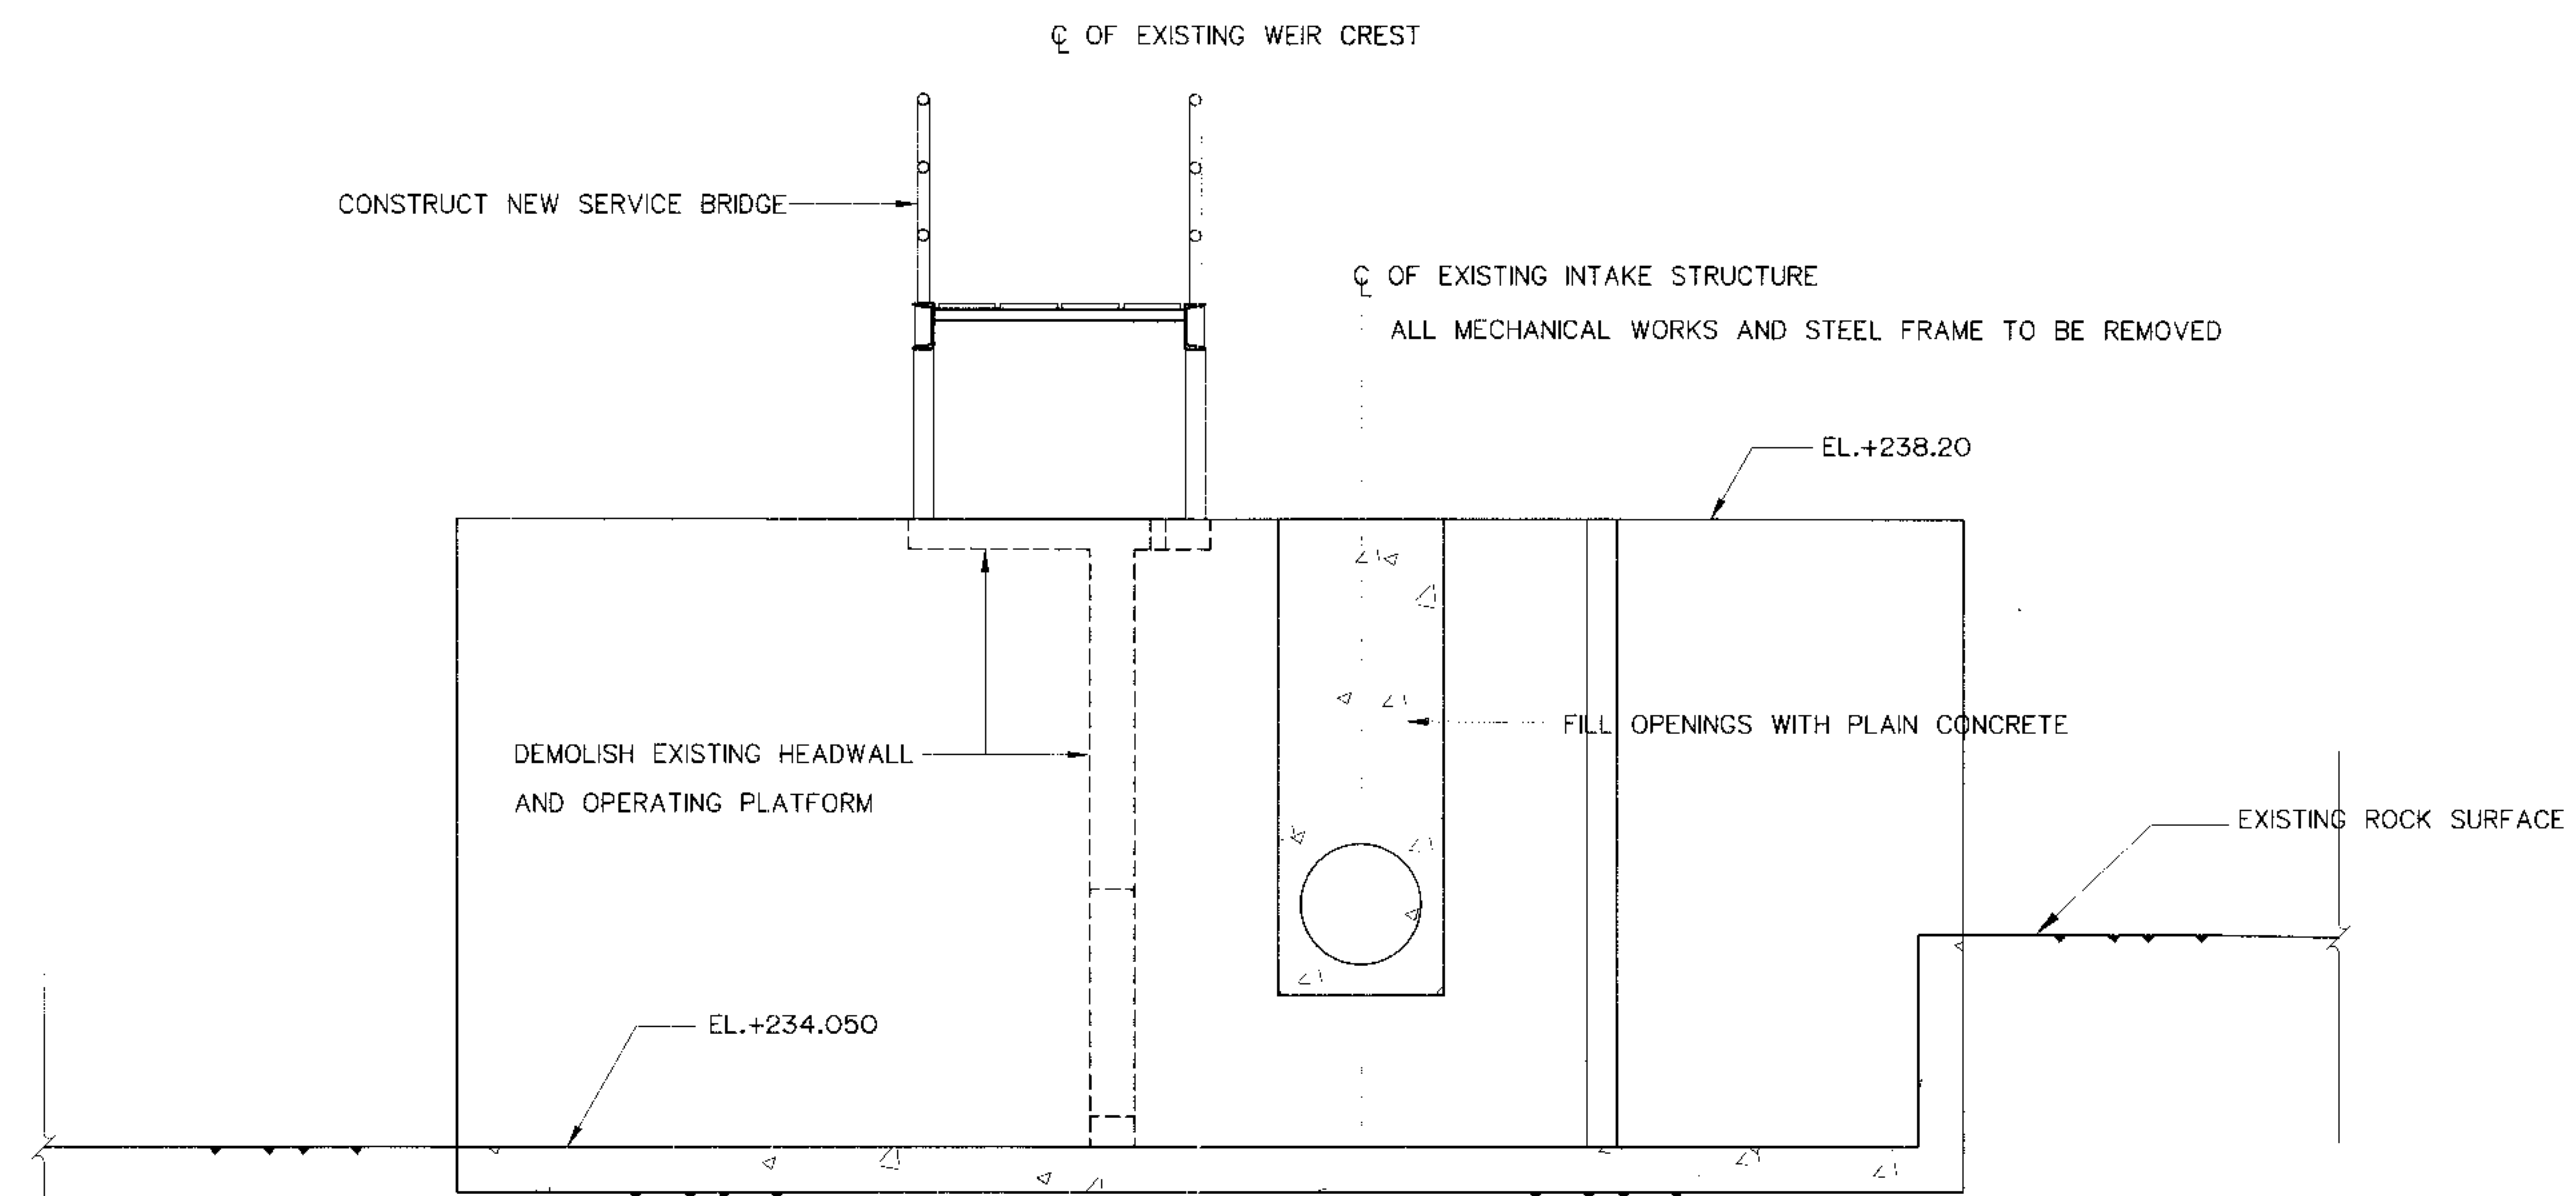

SECTION OF SLUICE WAY B-B
SCALE 1:50

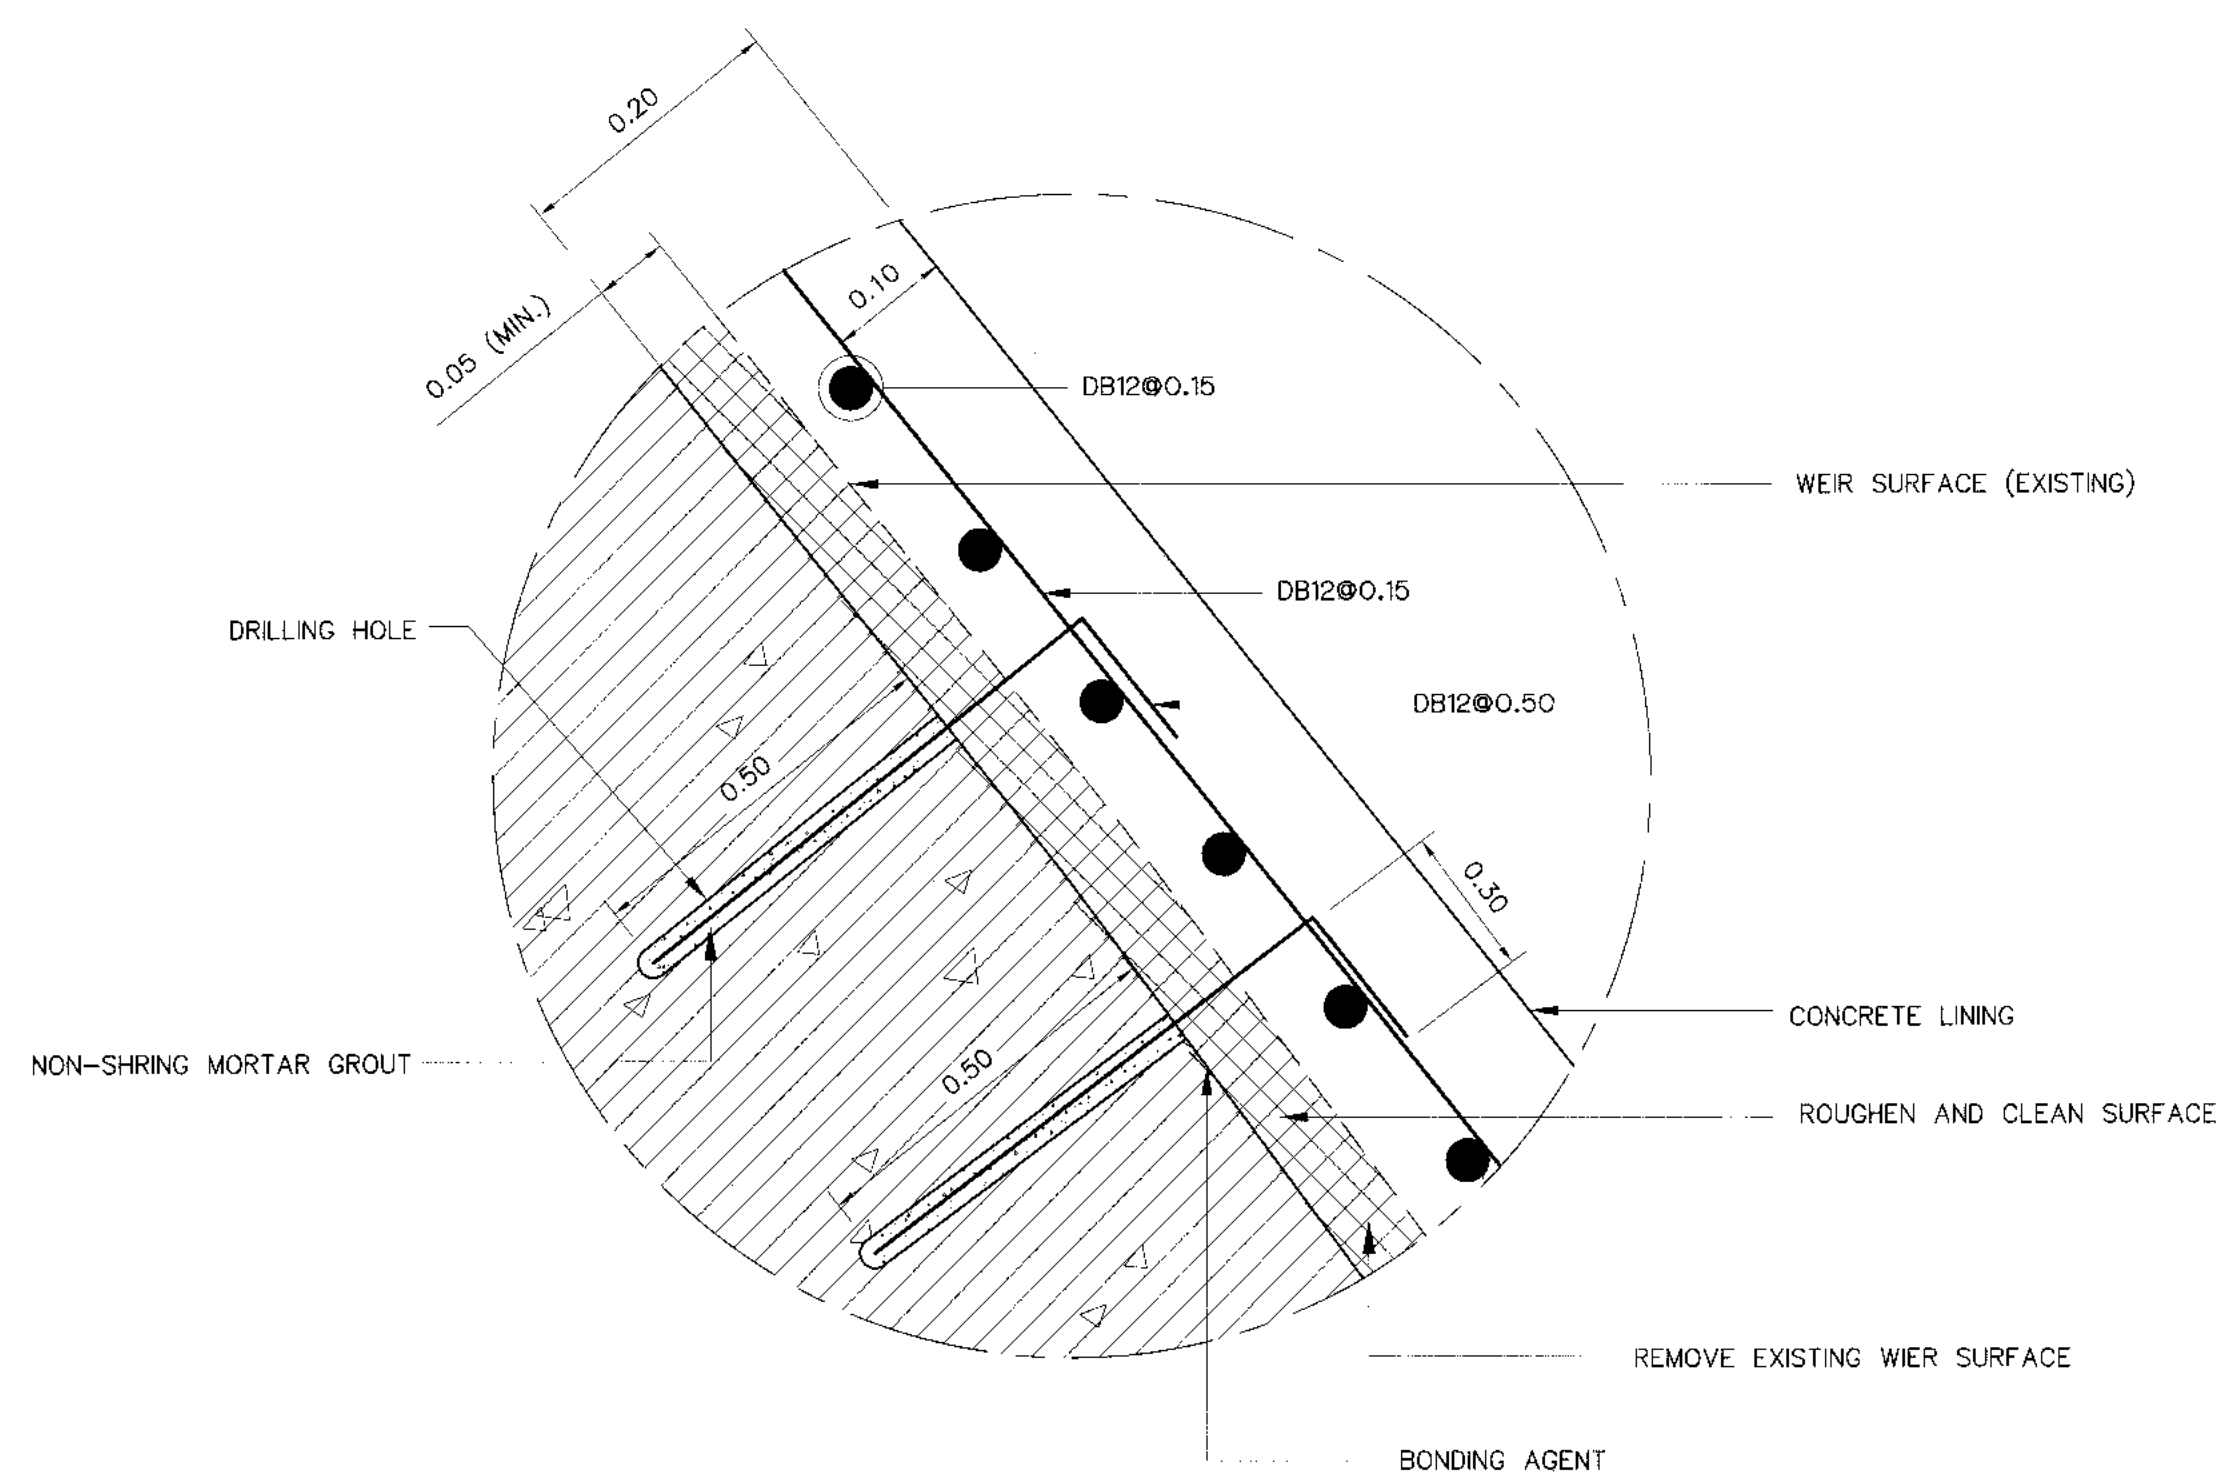

DETAIL "1"
SCALE 1:10

STEP OF LINING :

1. CONCRETE REMOVAL TECHNIQUES USED SHOULD BE EFFECTIVE, FAST, SAFE, ECONOMICAL AND ENVIRONMENTALLY FRIENDLY. THE EXISTING CONCRETE SURFACE MUST BE DRY, CLEAN, ROUGH AND FREE OF DUST SO THAT THE POURED CONCRETE WILL STICK TO THE OLD CONCRETE
2. THE REPAIRED SURFACE SHOULD BE CLEANED THOROUGHLY BY WET SAND BLASTING OR DRY SAND BLASTING OR SHOT BLASTING OR OTHER EQUIVALENT METHOD. FINALLY, IT SHOULD BE CLEANED BY WIND OR WATER USING PRESSURE.
3. A HOLE IS DRILLED TO INSTALL DOWEL BAR FIXED BY NON-SHRINK CEMENT GROUT AND INSTALL REINFORCED CONCRETE SO THAT THE POURED CONCRETE CAN REMAIN AND STICK TO THE OLD CONCRETE.
4. BEFORE POURING CONCRETE, APPLY MORTAR TO A THIN CONCRETE SURFACE NOT EXCEEDING 3 MM AND USE EPOXY RESIN BONDING AGENT, ASTM C881, TYPE II OR TYPE V.

NOTES :

1. ALL DIMENSIONS AND ELEVATIONS (M.S.L.) ARE IN METERS, UNLESS OTHERWISE SHOWN.
2. SYMBOLS, ABBREVIATIONS AND GENERAL NOTES SEE DWG. NO. KLP-GN-03
3. CONCRETE DESIGN BASED ON THE COMPRESSIVE STRENGTH OF 210 KSC, STANDARD CYLINDER Ø0.15x0.30 m. TEST AT AGE 28 DAYS. UNLESS OTHERWISE INDICATED IN SPECIFIC DRAWINGS.
4. ULTIMATE TENSILE STRESSES OF REINFORCING STEEL, CONFORM TO THE REQUIREMENT OF THAI INDUSTRIAL STANDARD DESIGNATION SR24 FOR STRUCTURAL GRADE PLAIN ROUND BAR AND SD30 FOR INTERMEDIATE GRADE DEFORMED BAR.












REFERENCE DRAWINGS :

1. WEIR : WEIR REHABILITATION GENERAL LAY-OUT KLP-WE-01



3				
2				
1				
NO.	DATE	REVISIONS	CHECKED	APPROVED
		CONSULTANTS	DEDE	

KINGDOM OF THAILAND Department of Alternative Energy Development and Efficiency MINISTRY OF ENERGY	
KLONG LAM PLOK HYDROPOWER PROJECT	
CIVIL WORKS AND TRANSMISSION LINE WEIR : WEIR REHABILITATION SECTION AND DETAILS	
P&C MANAGEMENT CO.,LTD.	REVIEWED
DESIGNED 11/11/2564 09/03/2565	SUBMITTED
DRAWN	RECOMMENDED
CHECKED 09/03/2565	APPROVED
PROJECT MANAGER	DATE
DRAWING NO. KLP-WE-02	SHEET NO. 11 OF 110

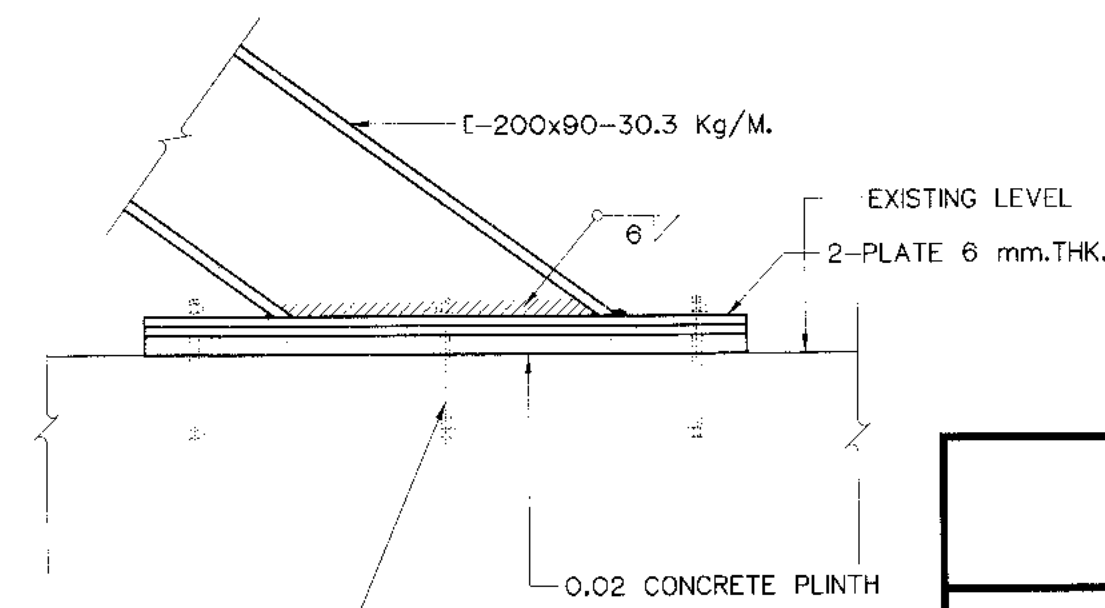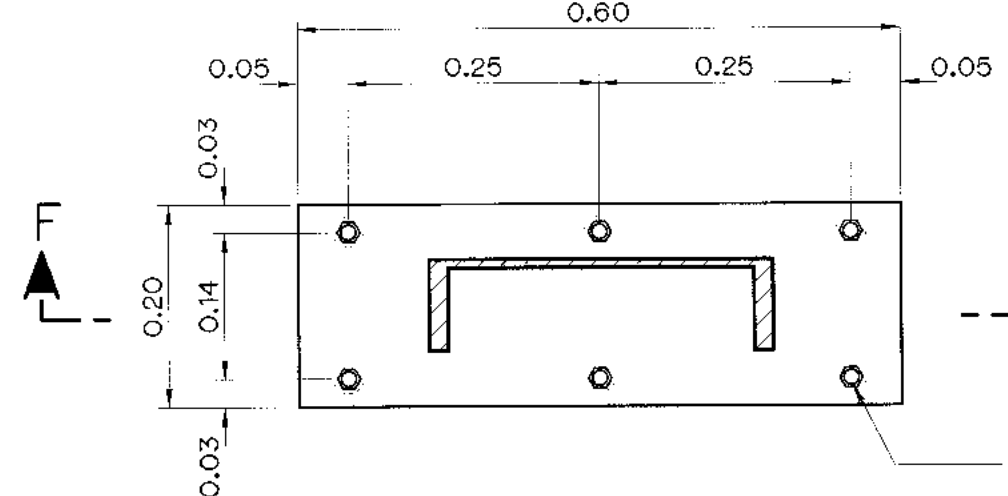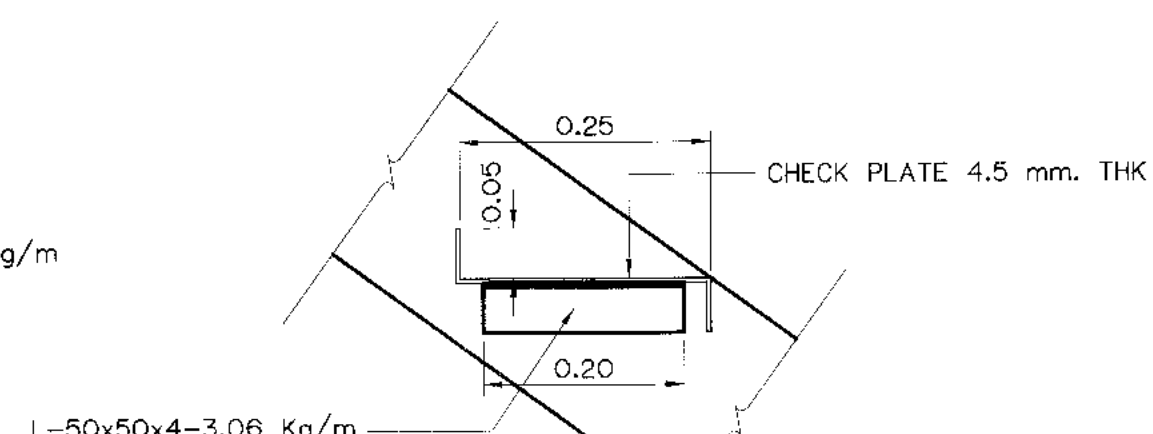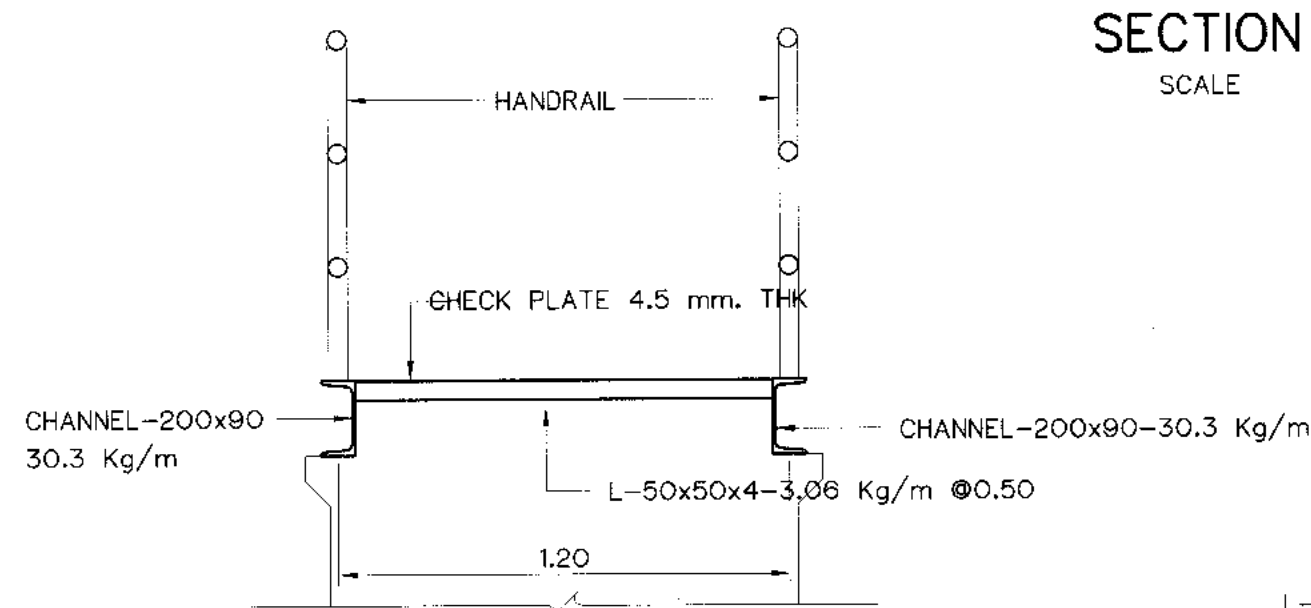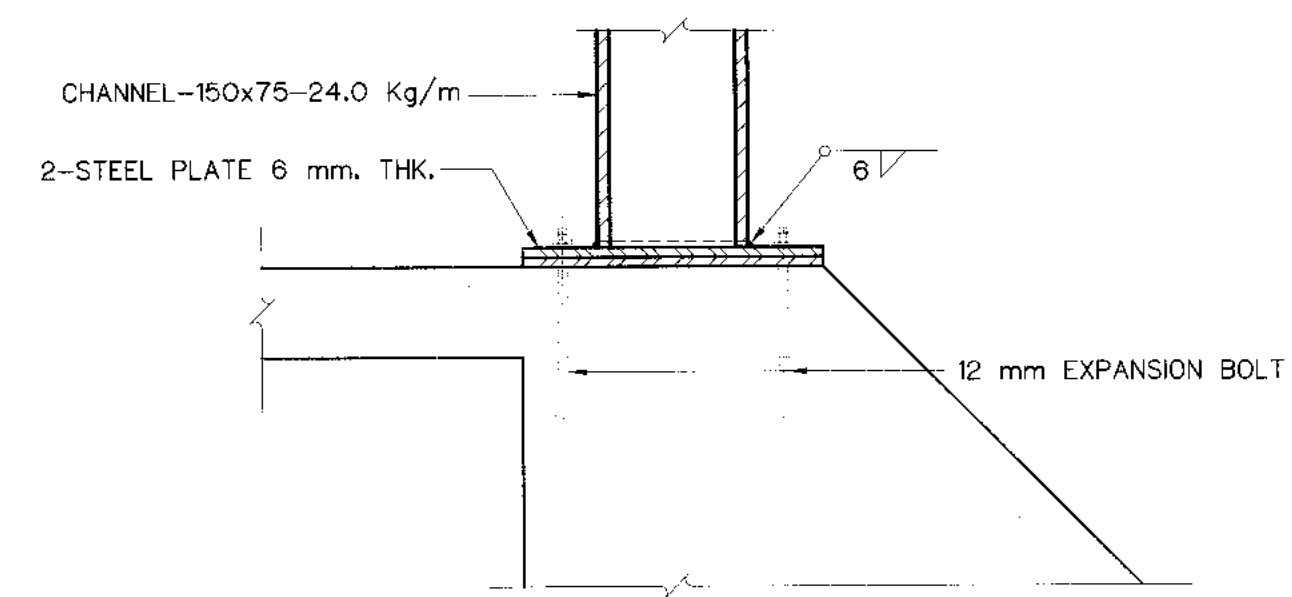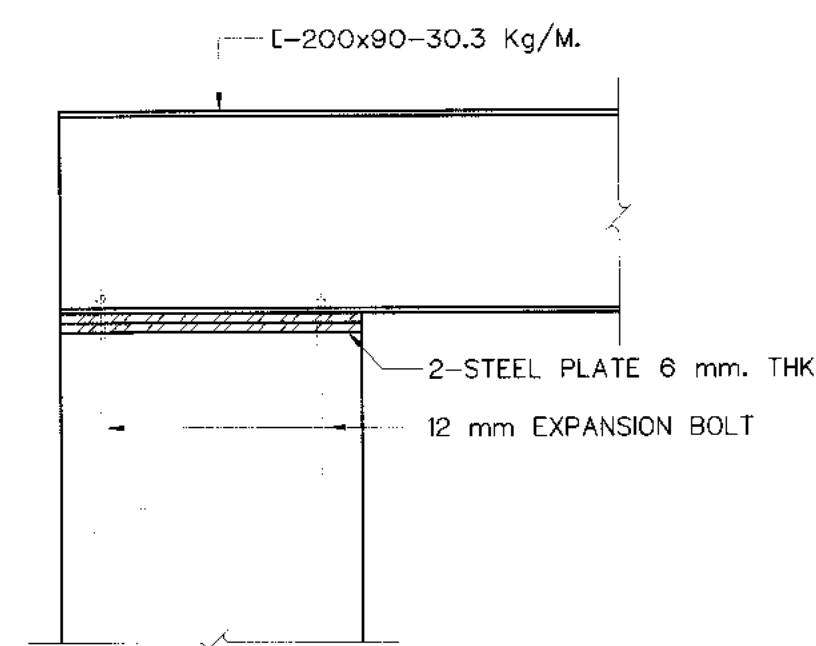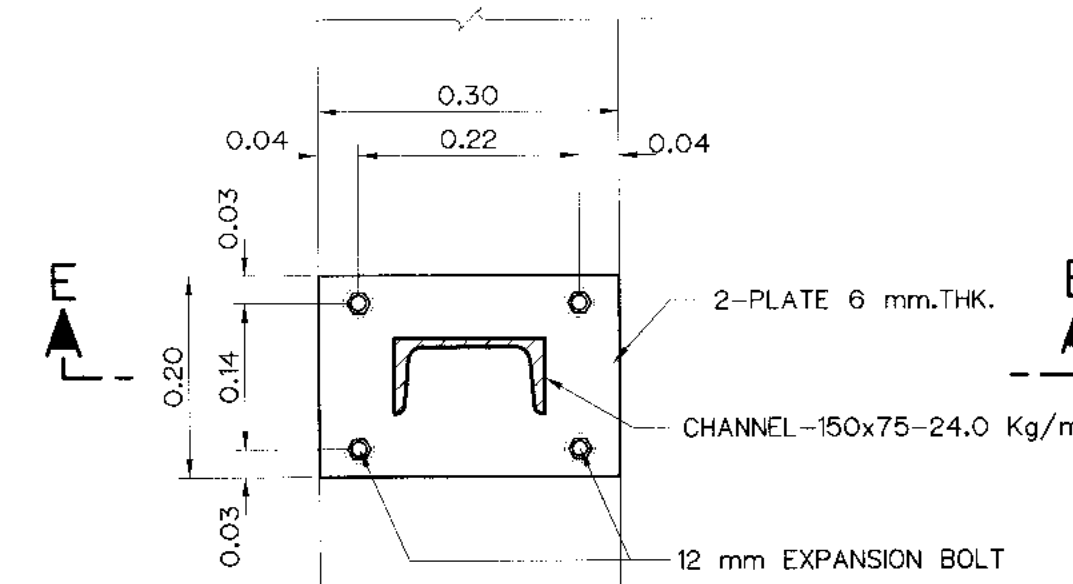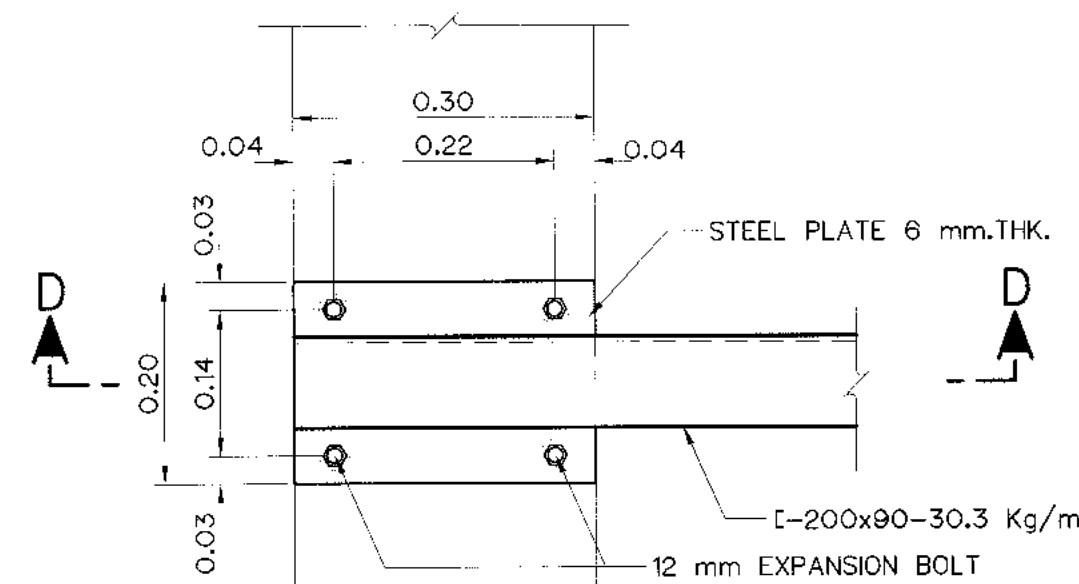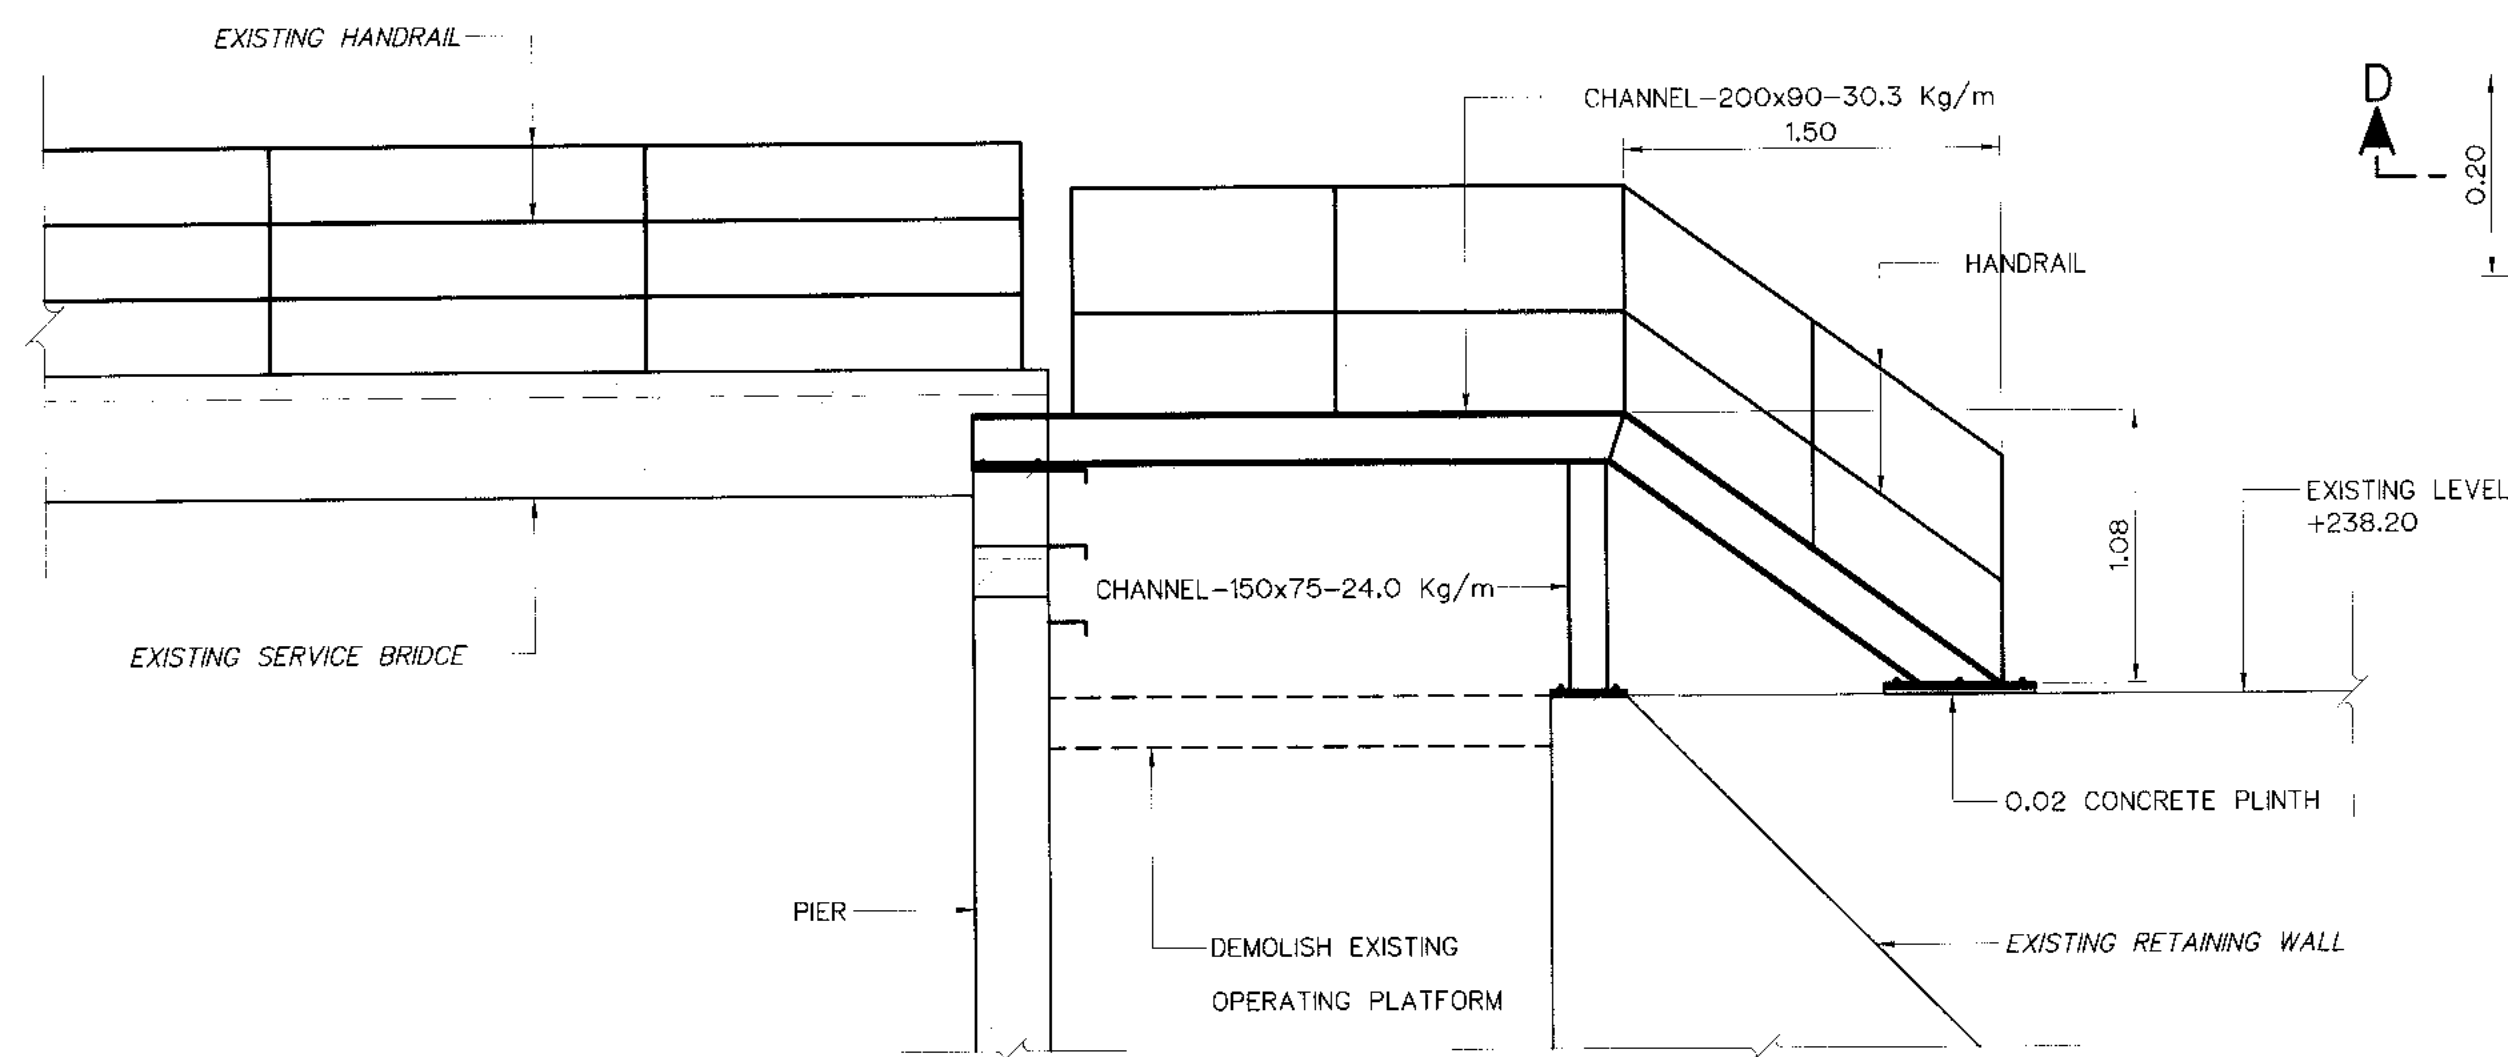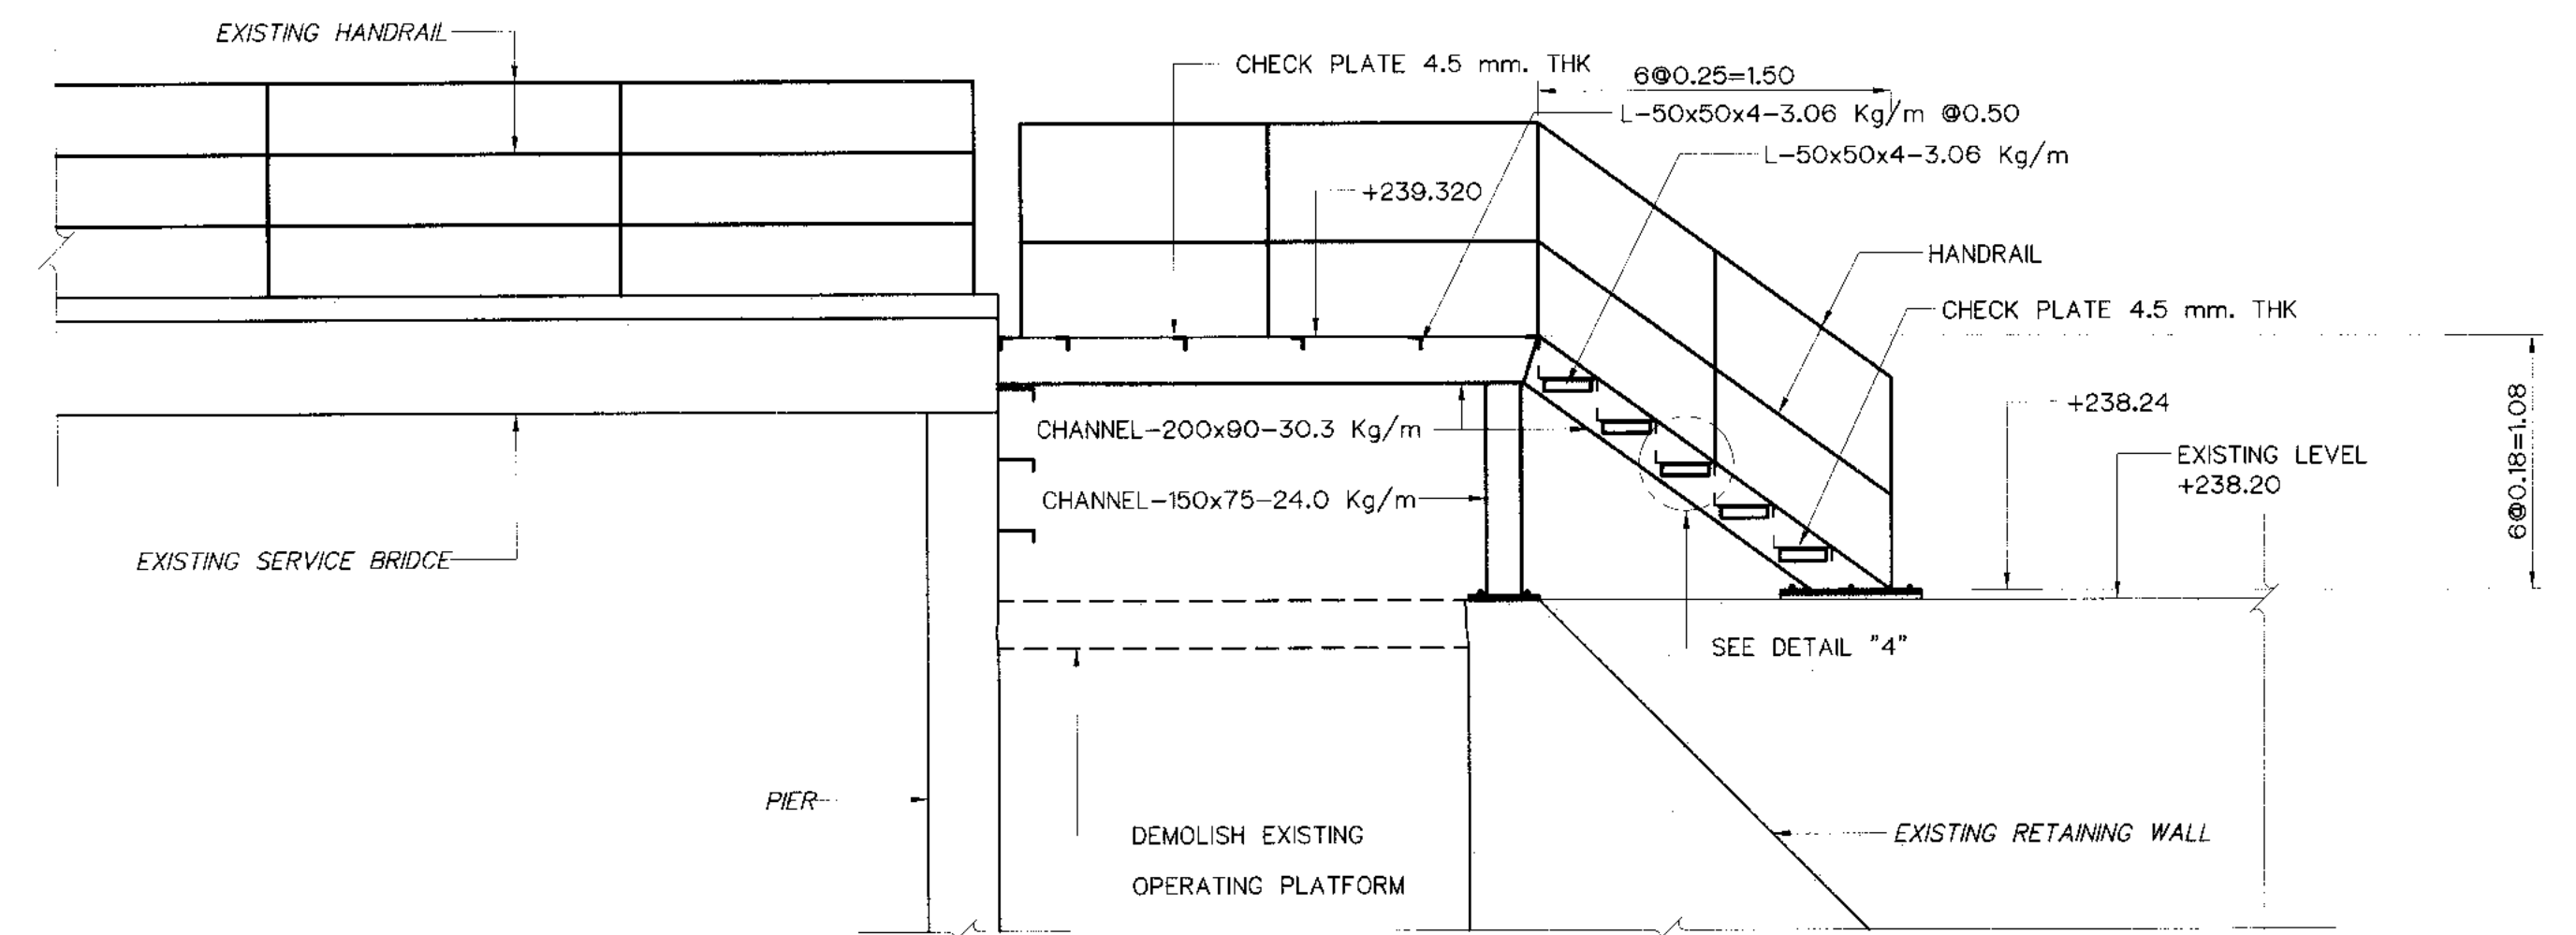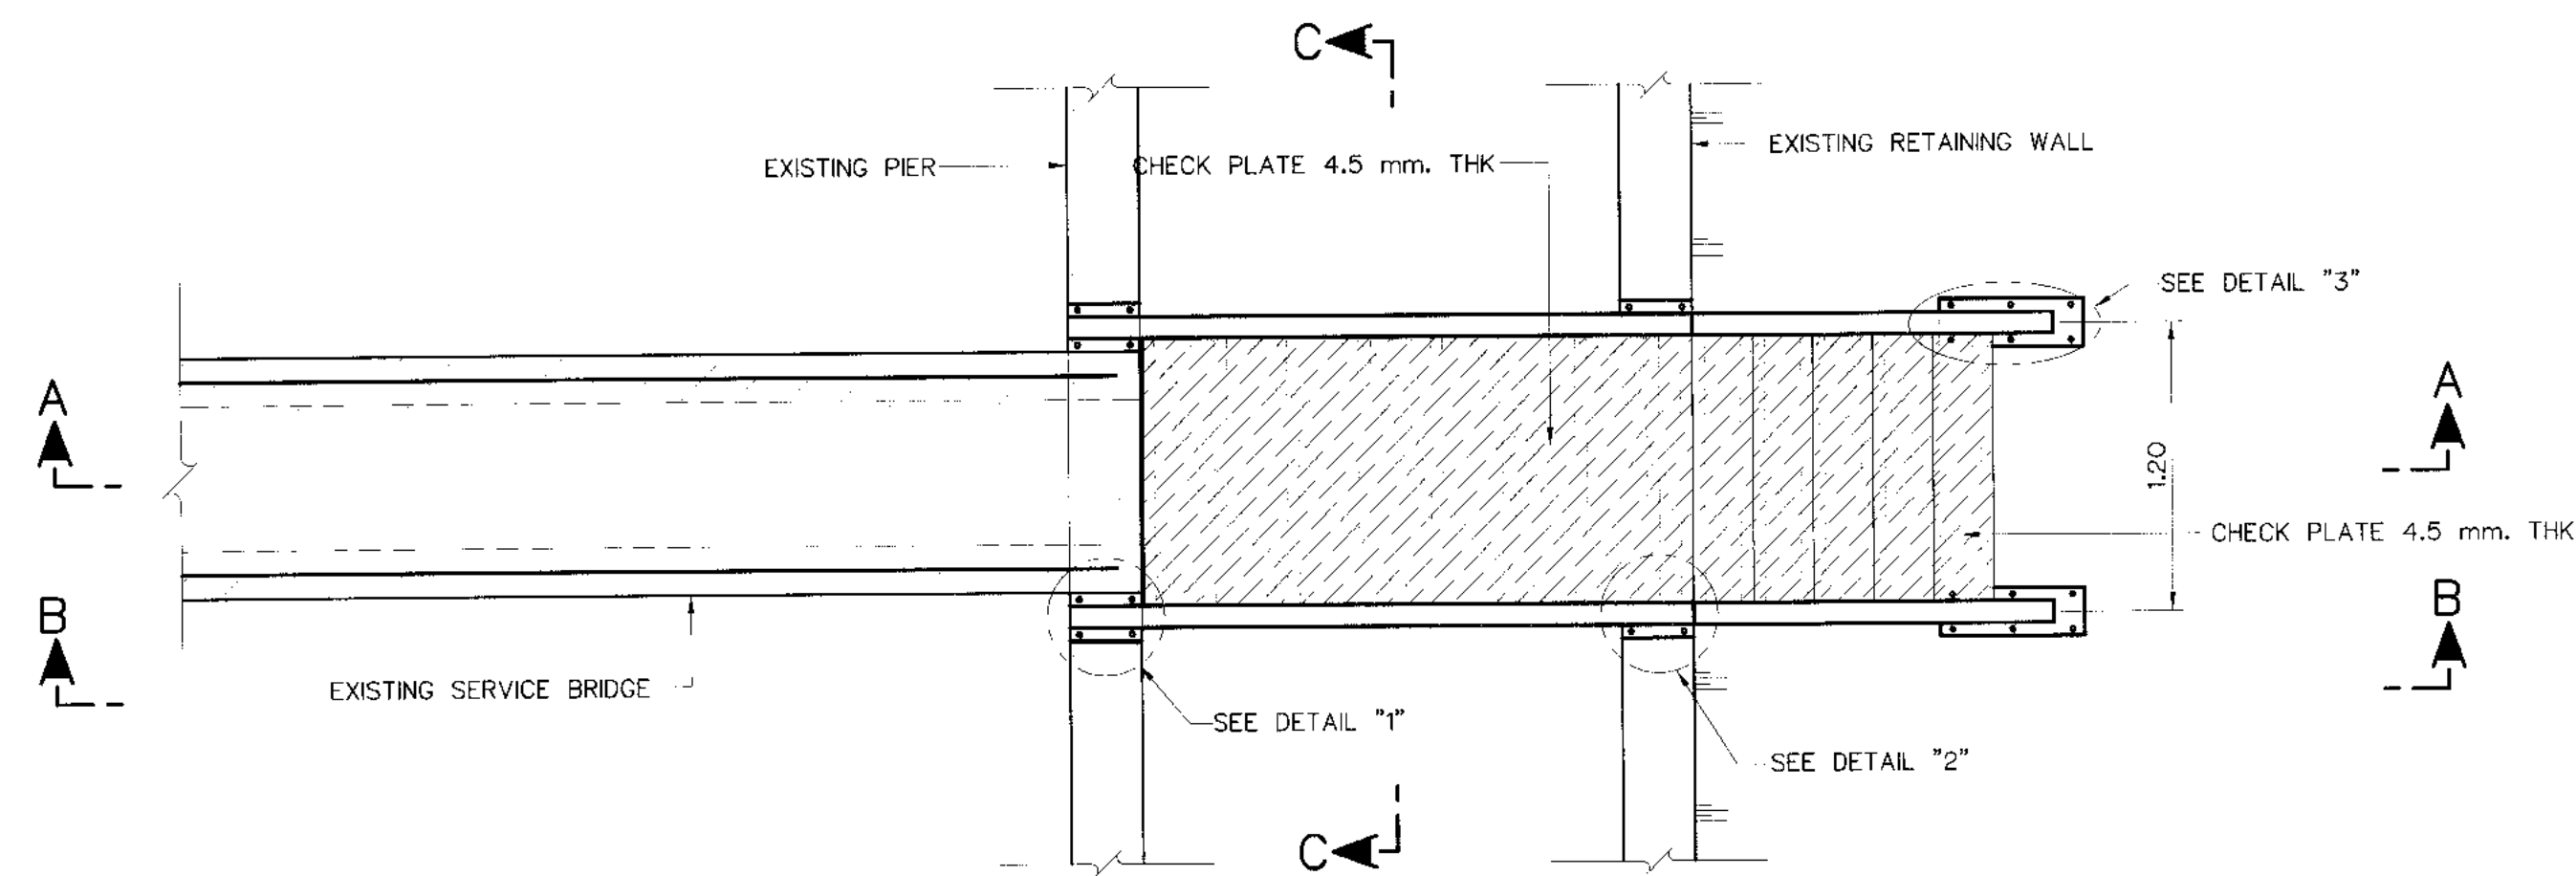


NOTES :


- ALL DIMENSIONS AND ELEVATIONS (M.S.L.) ARE IN METERS, UNLESS OTHERWISE SHOWN.
- SYMBOLS, ABBREVIATIONS AND GENERAL NOTES SEE DWG. NO. KLP-GN-03
- SPACING OF HANDRAIL CAN BE ADJUSTED IN THE FIELD TO FIT WITH THE STRUCTURE BY CONTRACTOR AND APPROVED BY ENGINEER.
- WELDING CONNECTION USE 6 MM, UNLESS OTHERWISE SHOWN

REFERENCE DRAWINGS :

- WEIR : WEIR REHABILITATION GENERAL LAY-OUT KLP-WE-01

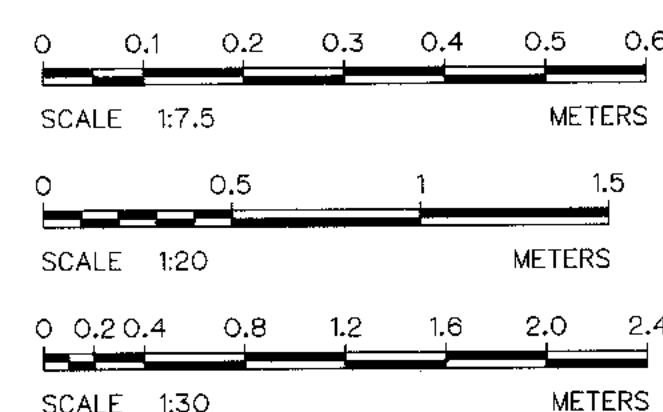

KINGDOM OF THAILAND Department of Alternative Energy Development and Efficiency MINISTRY OF ENERGY	
KLONG LAM PLOK HYDROPOWER PROJECT	
CIVIL WORKS AND TRANSMISSION LINE	
WEIR : WEIR REHABILITATION SERVICE BRIDGE	
P&C MANAGEMENT CO., LTD.	REVIEWED
DESIGNED <i>Th</i> 28.29074 0.28.6226	SUBMITTED <i>Chant</i>
DRAWN <i>Th</i>	RECOMMENDED
CHECKED <i>Th</i> 28.6226	APPROVED <i>P. H. S. S.</i>
PROJECT MANAGER	DRAWING NO. 08/03/2559
DATE	SHEET NO. 12 OF 110







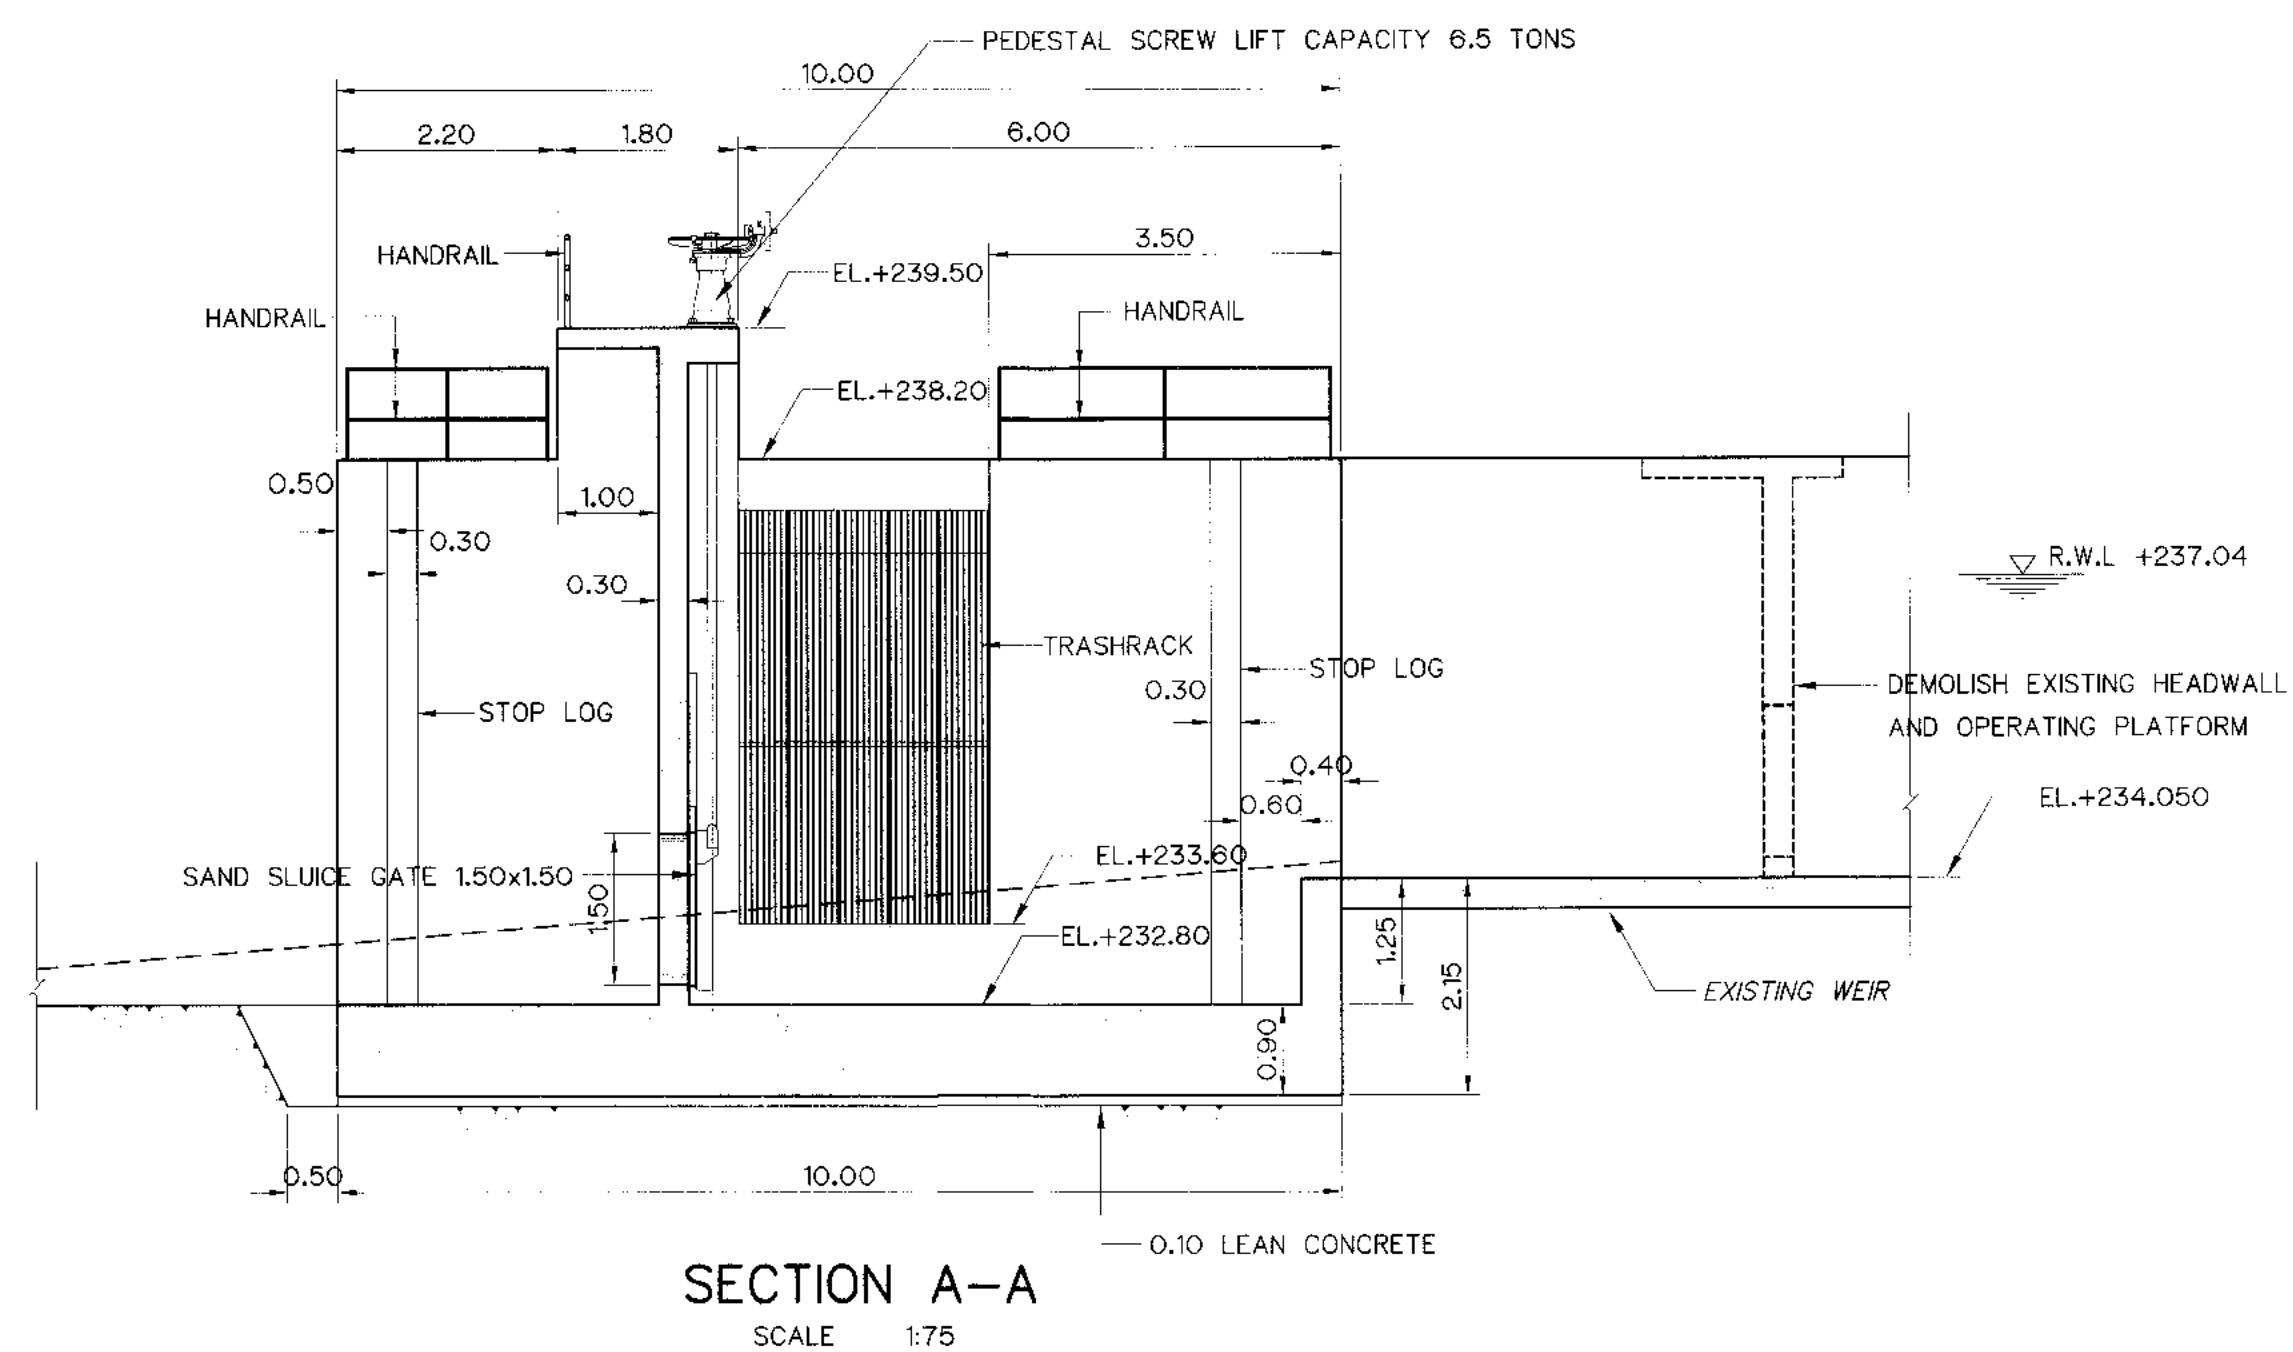
 EXISTING STRUCTURE

1. ALL DIMENSIONS AND ELEVATIONS (M.S.L.) ARE IN METERS, UNLESS OTHERWISE SHOWN.
2. SYMBOLS, ABBREVIATIONS AND GENERAL NOTES SEE DWG. NO. KLP-GN-03
3. SPACING OF HANDRAIL CAN BE ADJUSTED IN THE FIELD TO FIT WITH THE STRUCTURE BY CONTRACTOR AND APPROVED BY ENGINEER.
4. INTAKE SHALL BE PLACED ON BED ROCK FOUNDATION, OTHER MATERIALS SHALL BE REMOVED AND BACKFILLED WITH LEAN CONCRETE AND THE LEAN CONCRETE SHALL HAVE THE COMPRESSIVE STRENGTH OF 140 KSC. FOR STANDARD CYLINDER AT 28 DAYS.
5. ALLOWABLE BEARING CAPACITY NOT LESS THAN 15 TON/sq m.

1. WEIR : WEIR REHABILITATION GENERAL LAY-OUT KLP-WE-01



					 P&C MANAGEMENT CO., LTD.		 MINISTRY OF ENERGY	
3					DESIGNED	<i>W</i> ๒๕.๒๙๐74 ๐๒๖.๖2๒6	REVIEWED	<i>Handwritten Signature</i>
2					DRAWN	<i>Handwritten Signature</i>	SUBMITTED	<i>Charnit</i>
1					CHECKED	<i>Handwritten Signature</i> ๐๒๖.๖2๒6	RECOMMENDED	<i>Handwritten Signature</i>
NO.	DATE	REVISIONS	CHECKED	APPROVED	CHECKED		APPROVED	<i>P. Harnsri</i>
CONSULTANTS					DEDE		DRAWING NO.	SHEET NO.
					 08/03/2559 PROJECT MANAGER DATE		KLP-WE-04	13 of 110

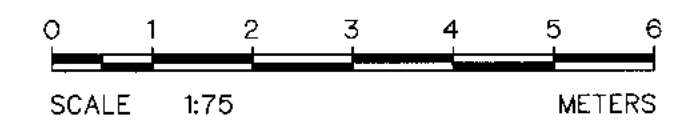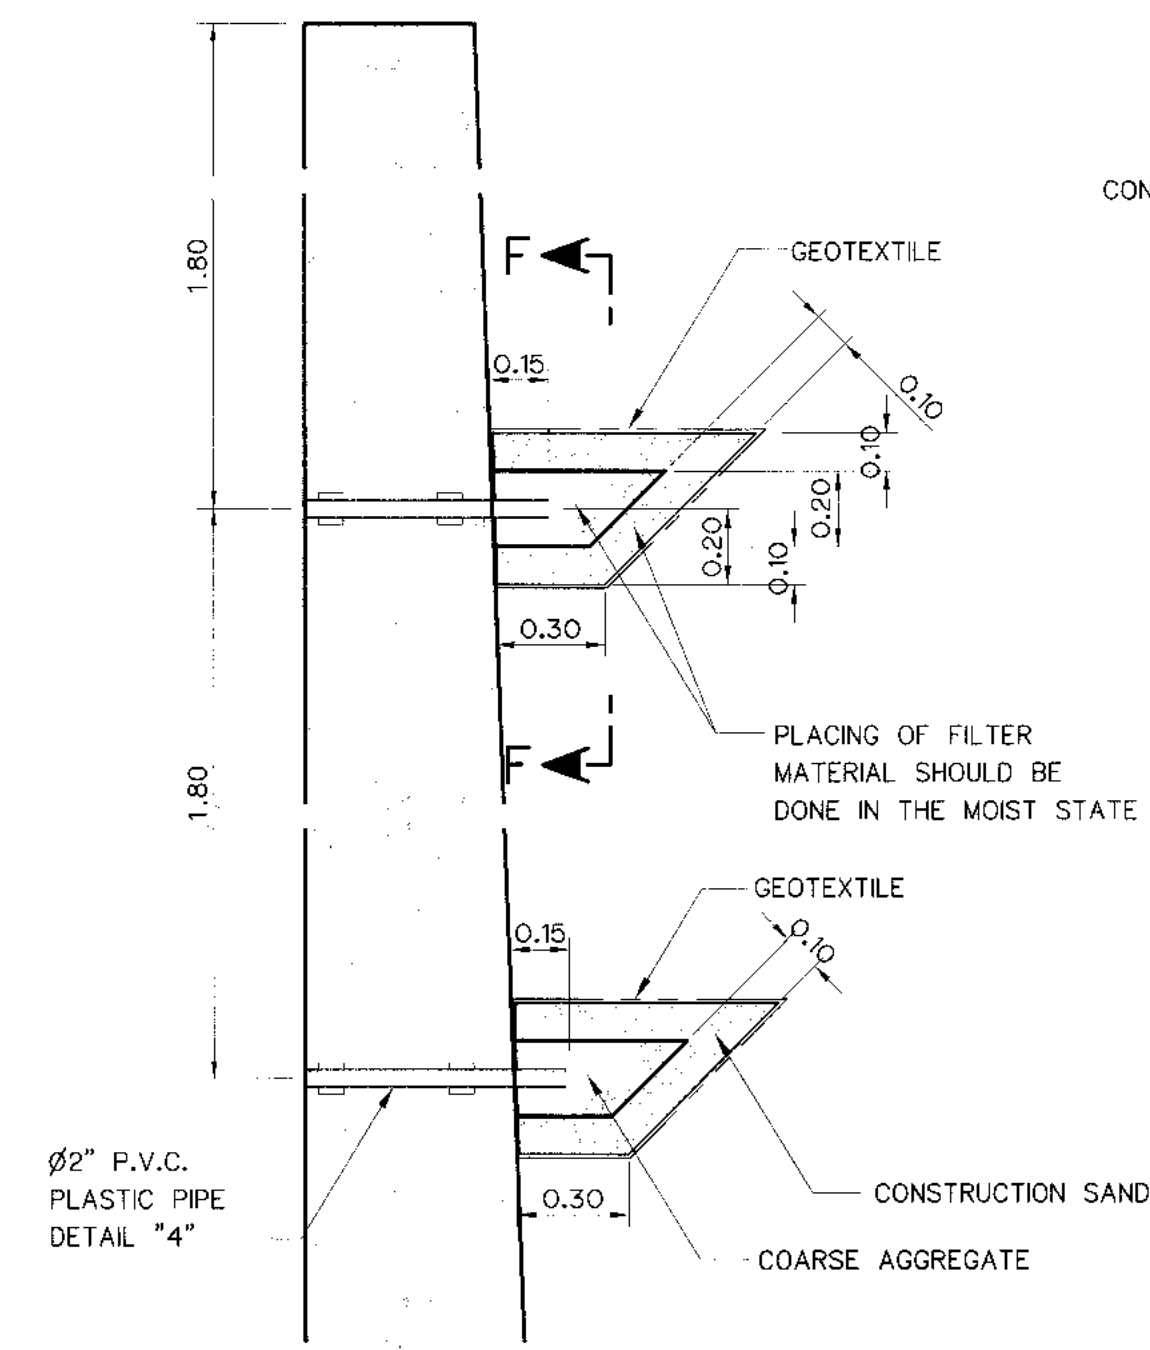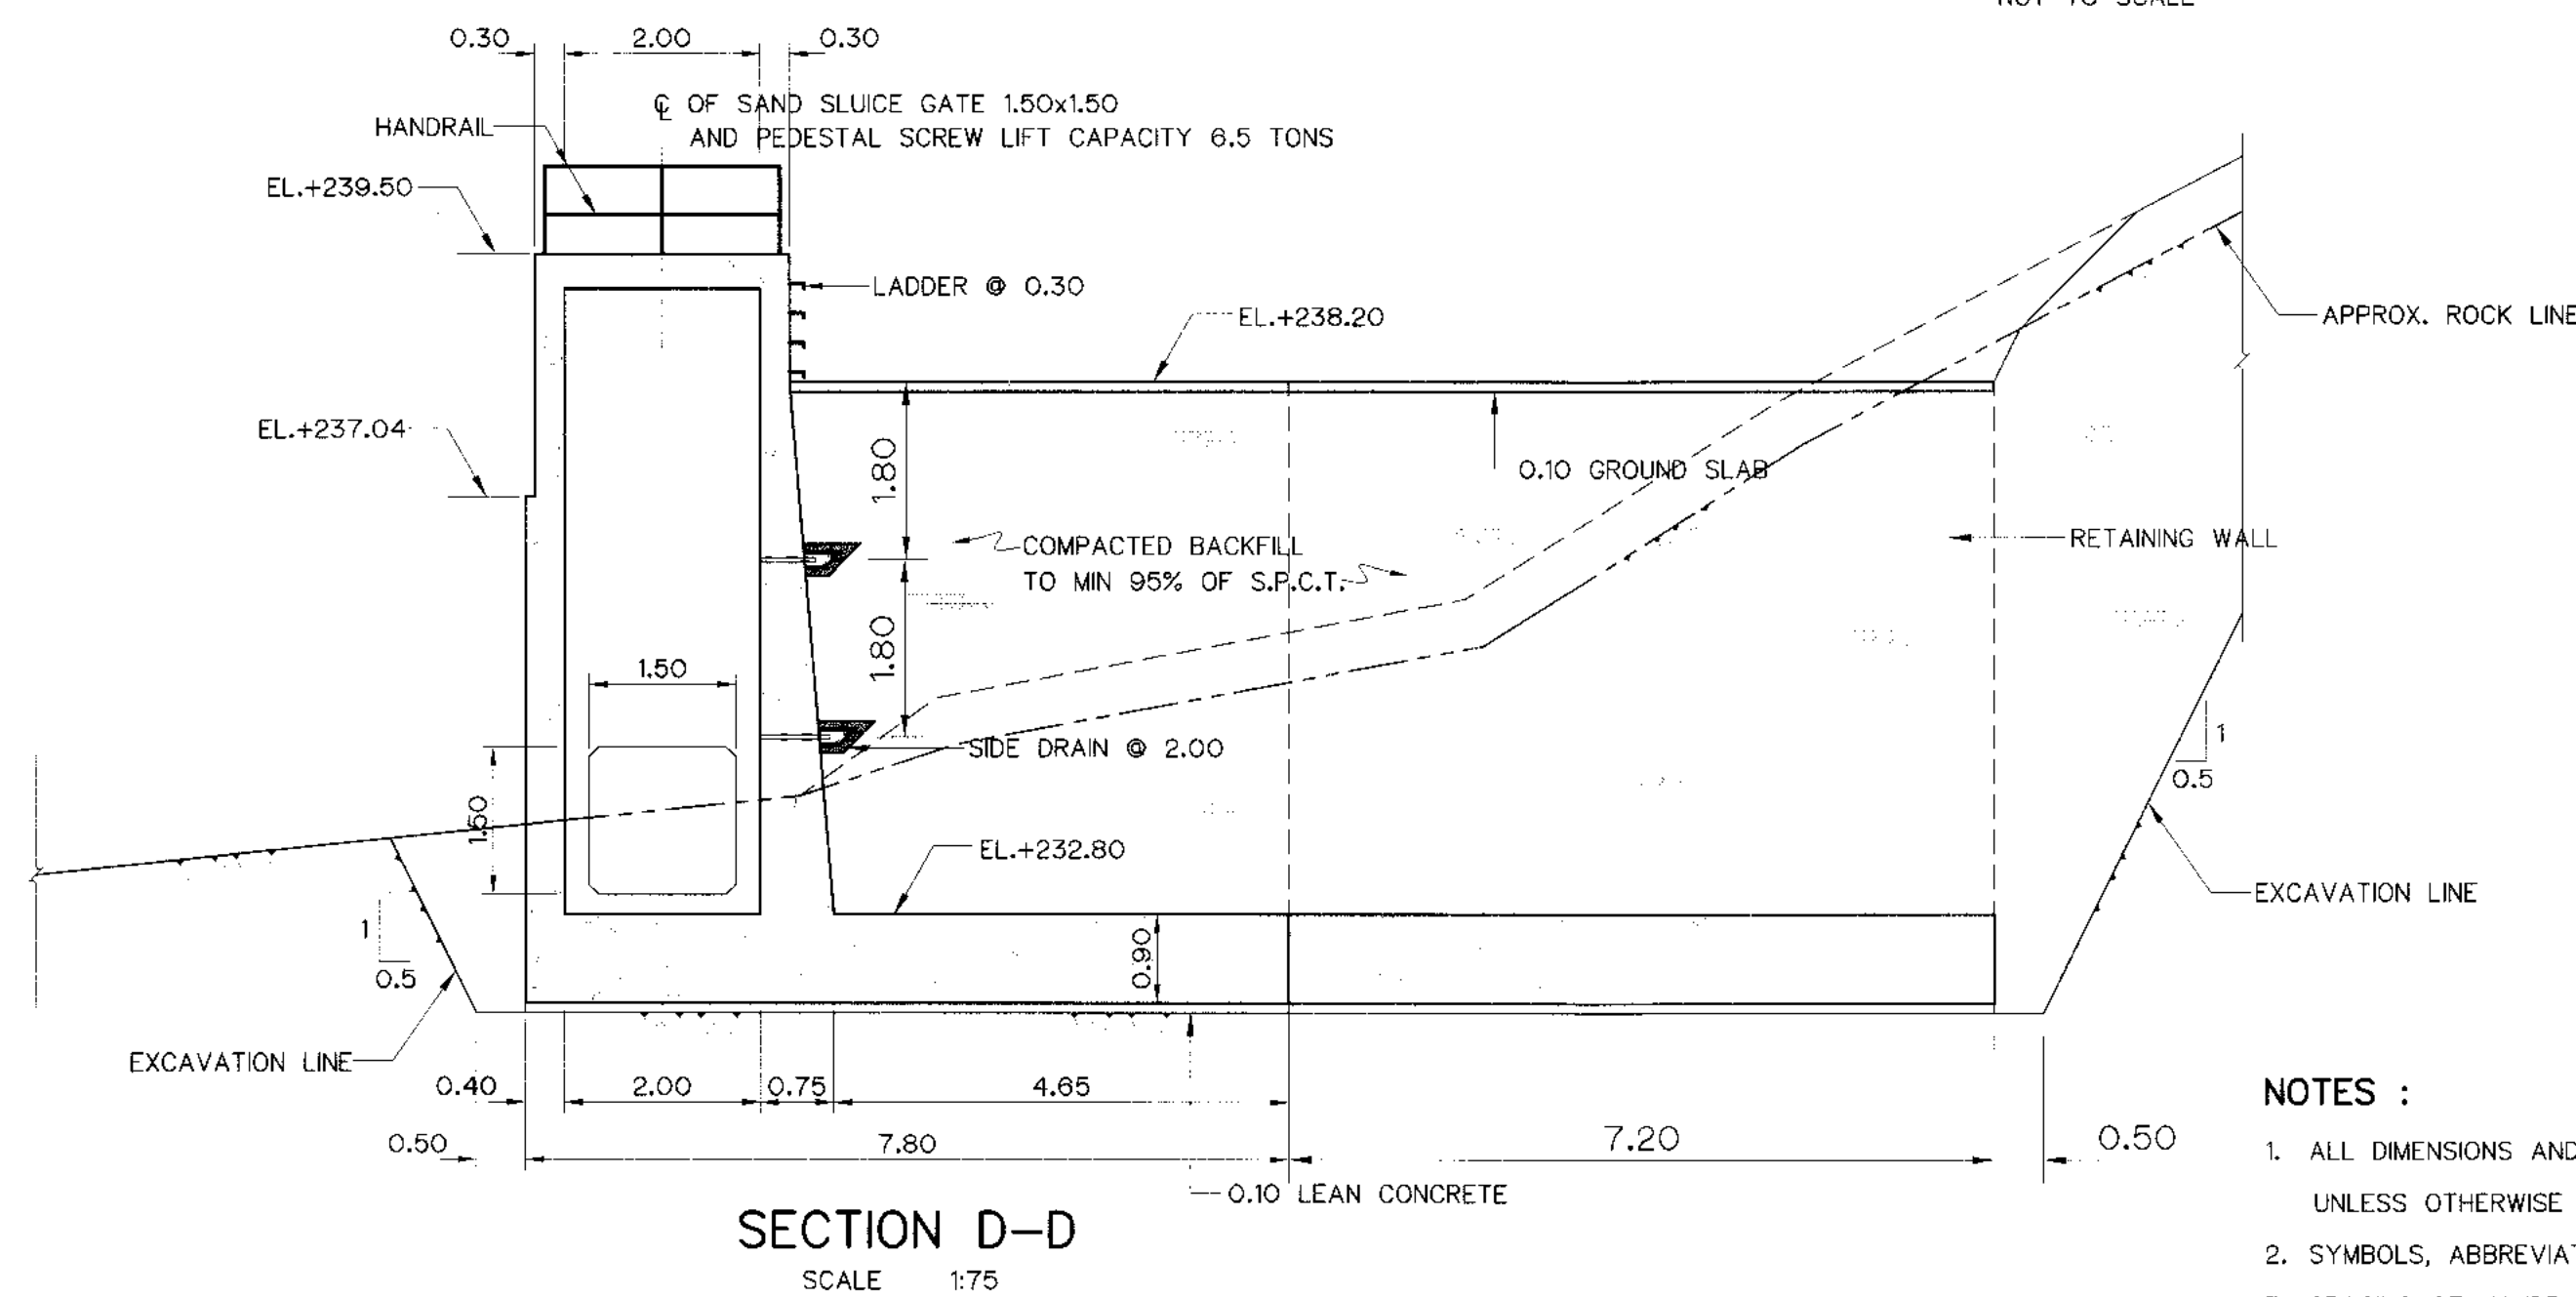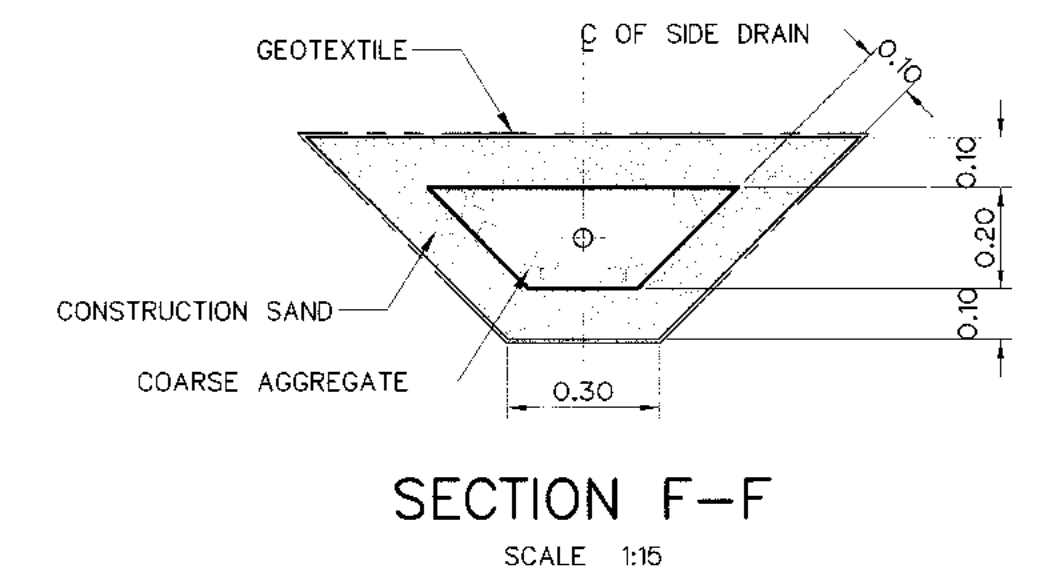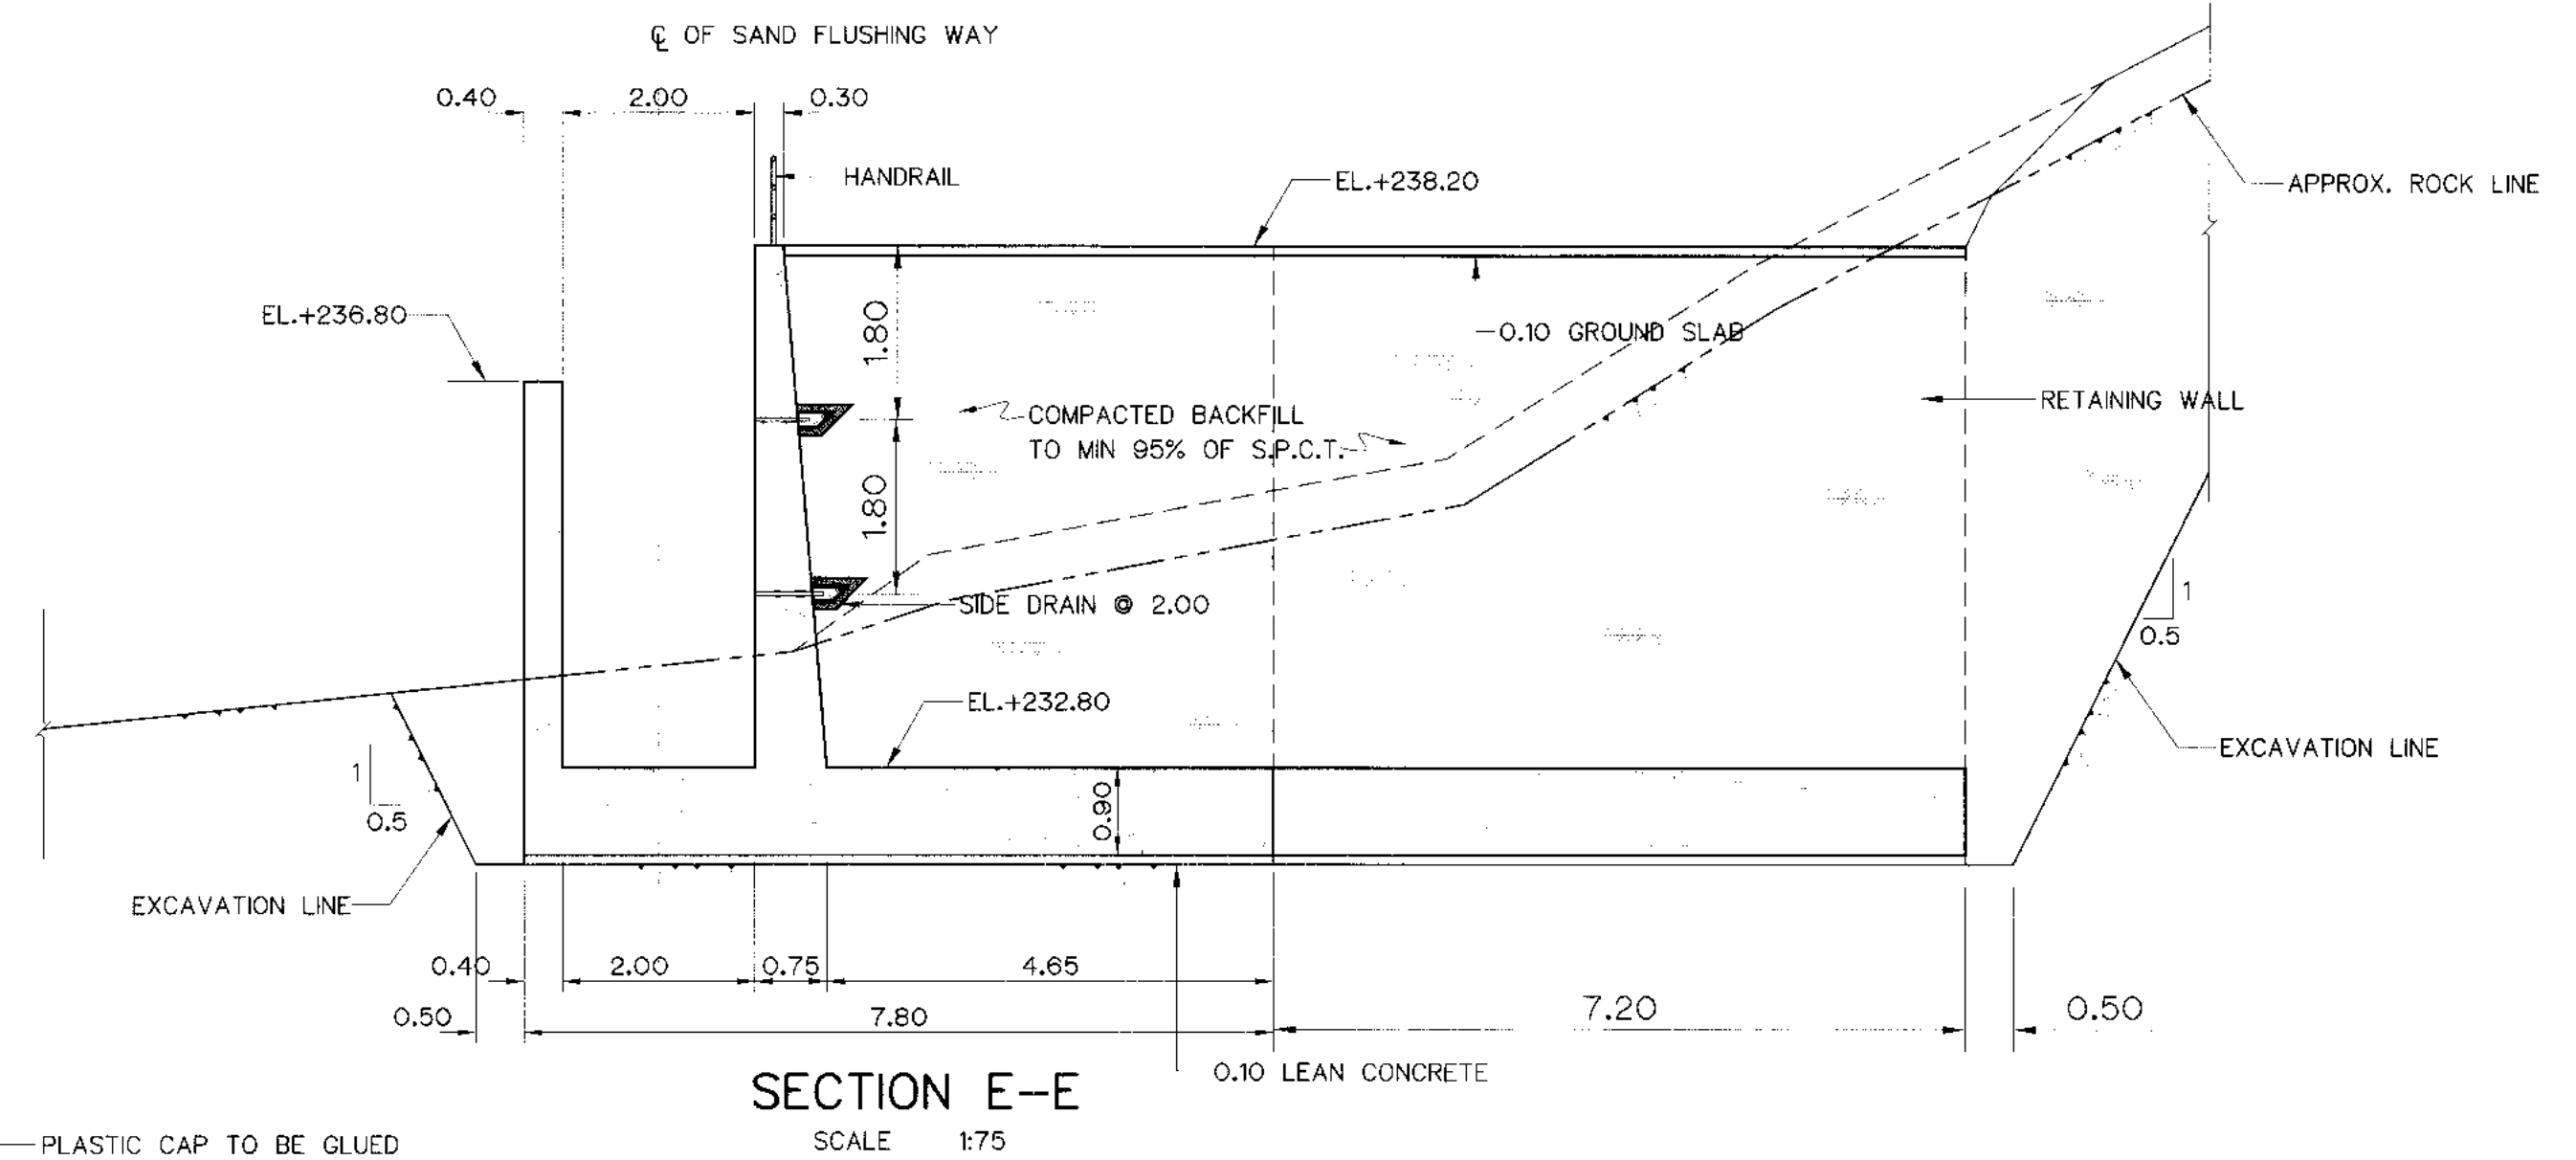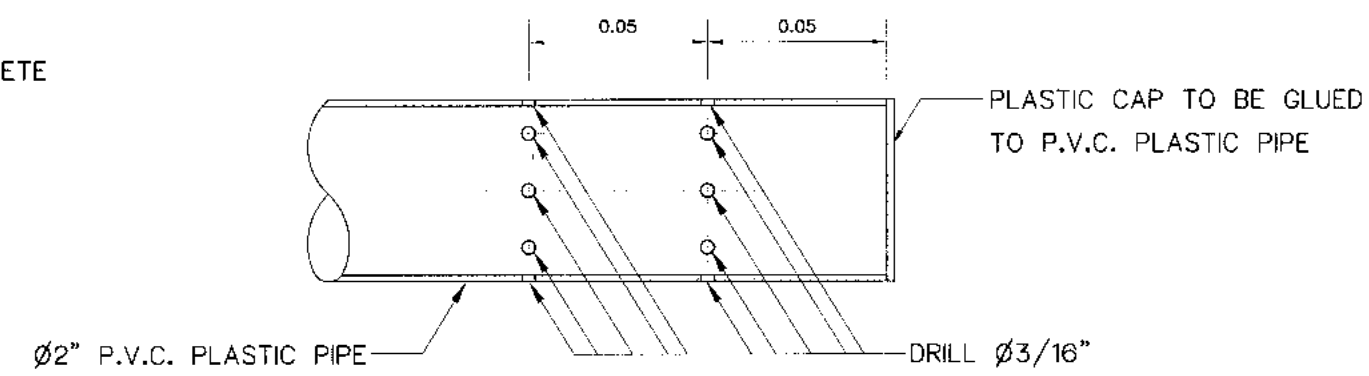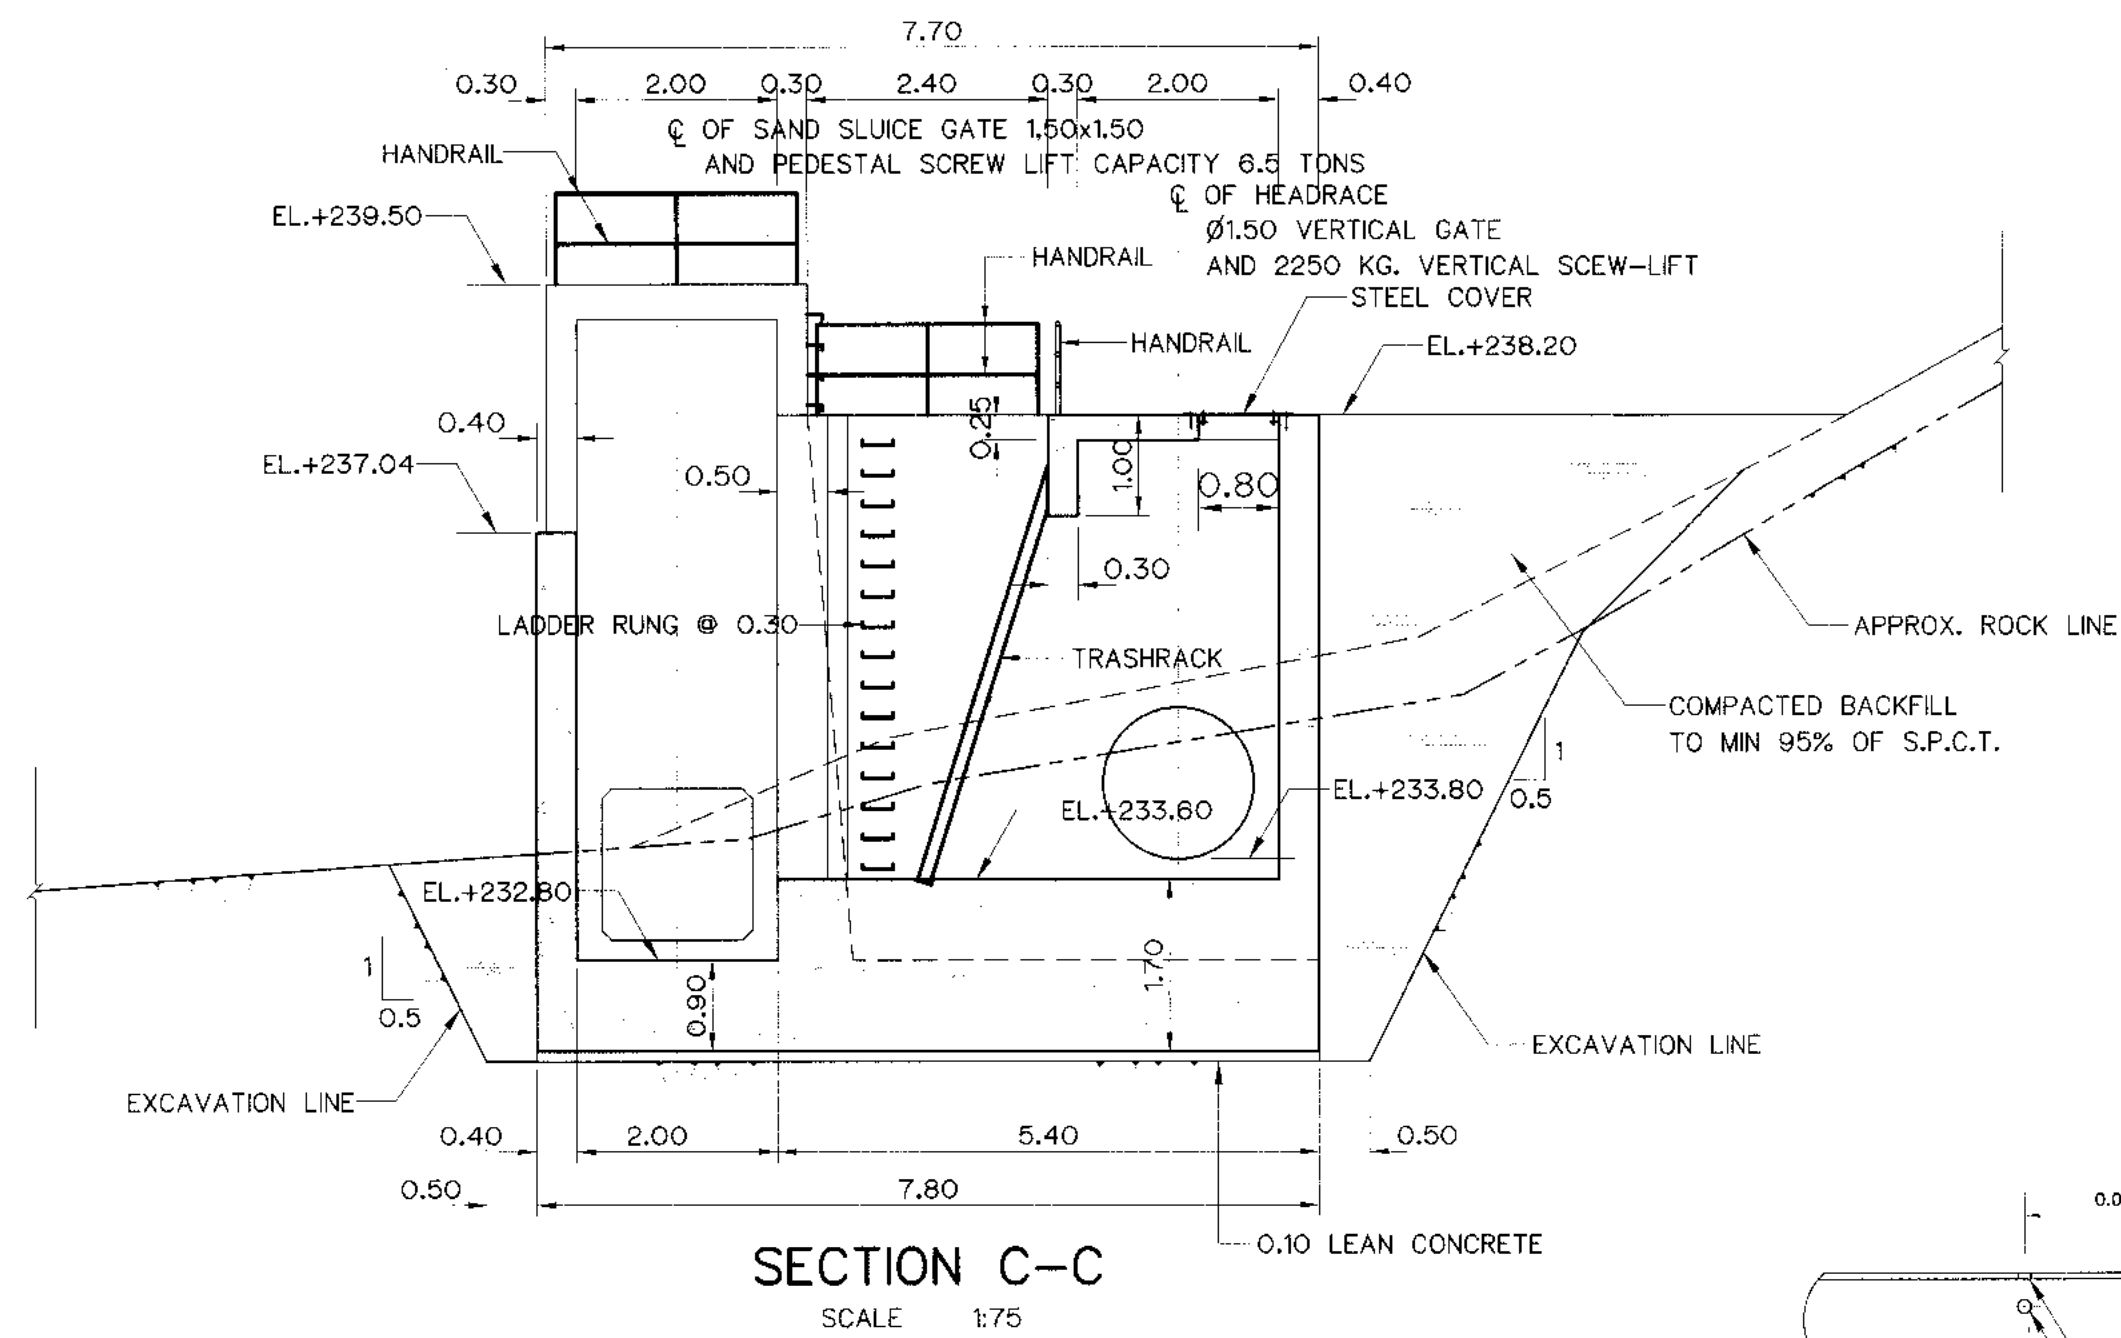

NOTES :






- ALL DIMENSIONS AND ELEVATIONS (M.S.L.) ARE IN METERS, UNLESS OTHERWISE SHOWN.
- SYMBOLS, ABBREVIATIONS AND GENERAL NOTES SEE DWG. NO. KLP-GN-03
- SPACING OF HANDRAIL CAN BE ADJUSTED IN THE FIELD TO FIT WITH THE STRUCTURE BY CONTRACTOR AND APPROVED BY ENGINEER.
- INTAKE SHALL BE PLACED ON BED ROCK FOUNDATION, OTHER MATERIALS SHALL BE REMOVED AND BACKFILLED WITH LEAN CONCRETE AND THE LEAN CONCRETE SHALL HAVE THE COMPRESSIVE STRENGTH OF 140 KSC. FOR STANDARD CYLINDER AT 28 DAYS.
- ALLOWABLE BEARING CAPACITY NOT LESS THAN 15 TON/sq m.

REFERENCE DRAWINGS :

- WEIR : INTAKE STRUCTURE PLAN AND SECTIONS KLP-WE-04

3				
2				
1				
NO.	DATE	REVISIONS	CHECKED	APPROVED

KINGDOM OF THAILAND Department of Alternative Energy Development and Efficiency MINISTRY OF ENERGY	
KLONG LAM PLOK HYDROPOWER PROJECT	
CIVIL WORKS AND TRANSMISSION LINE	
WEIR : INTAKE STRUCTURE	
SECTIONS	
P&C MANAGEMENT CO.,LTD.	REVIEWED
DESIGNED <i>[Signature]</i> 28.6.228	SUBMITTED <i>[Signature]</i>
DRAWN <i>[Signature]</i>	RECOMMENDED <i>[Signature]</i>
CHECKED <i>[Signature]</i> 28.6.228	APPROVED <i>[Signature]</i>
<i>[Signature]</i> 08/03/2559 PROJECT MANAGER DATE	DRAWING NO. KLP-WE-05 SHEET NO. 14 OF 110

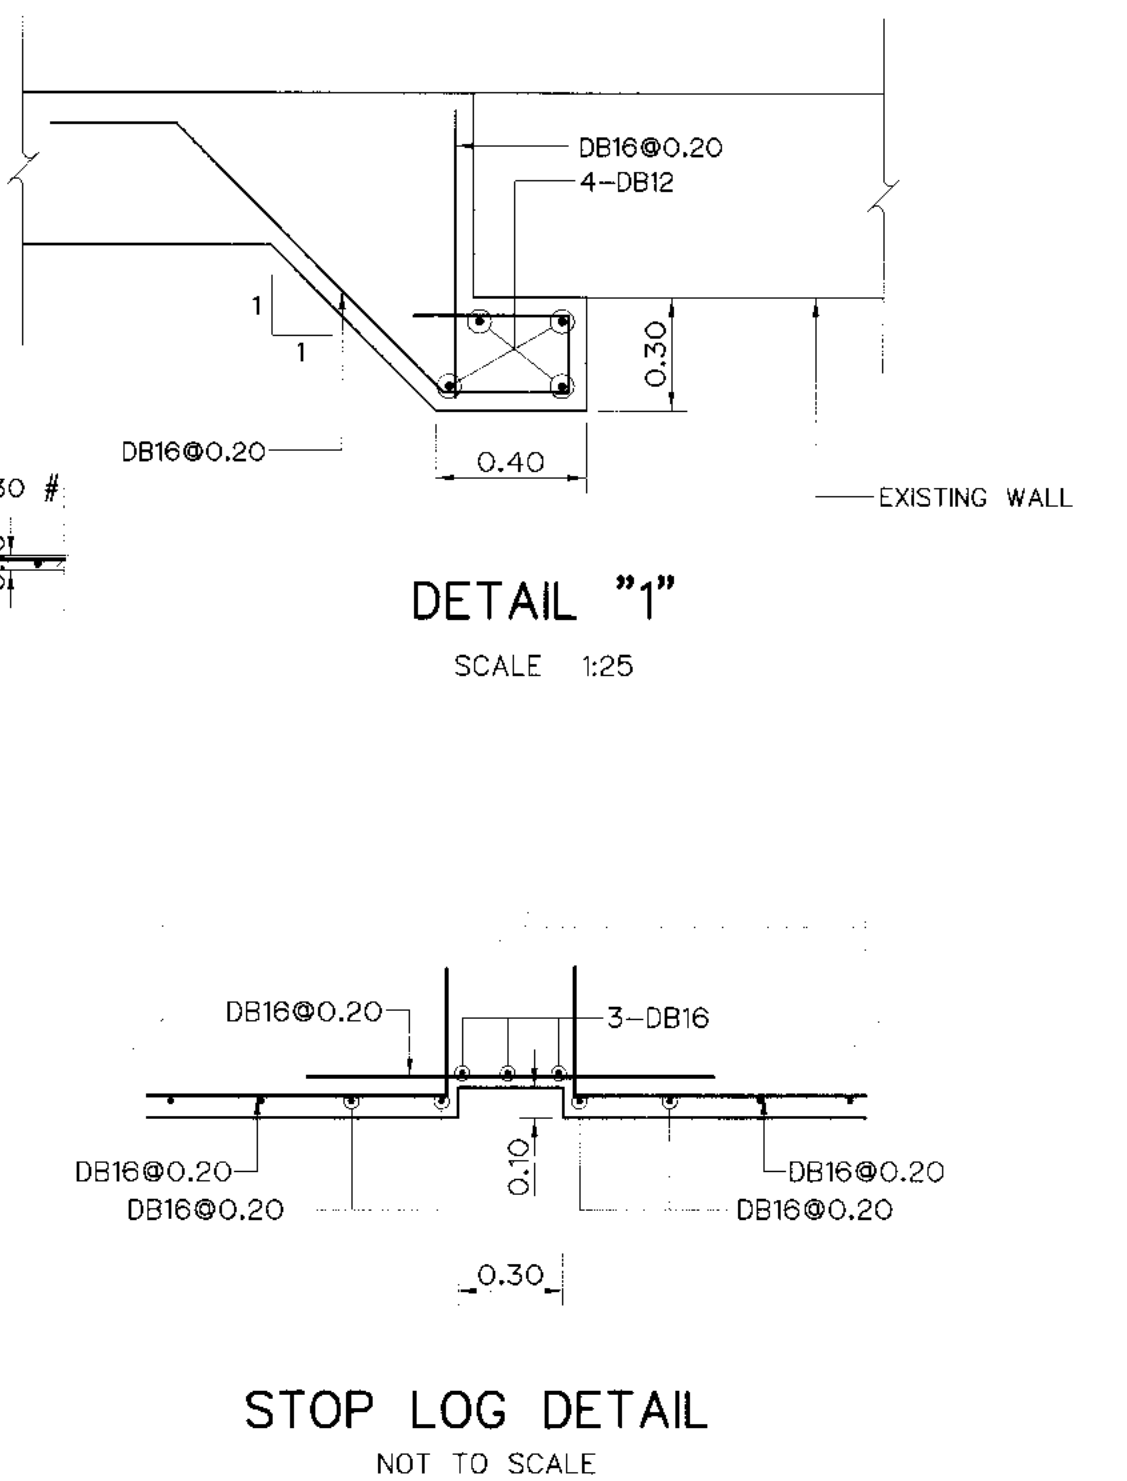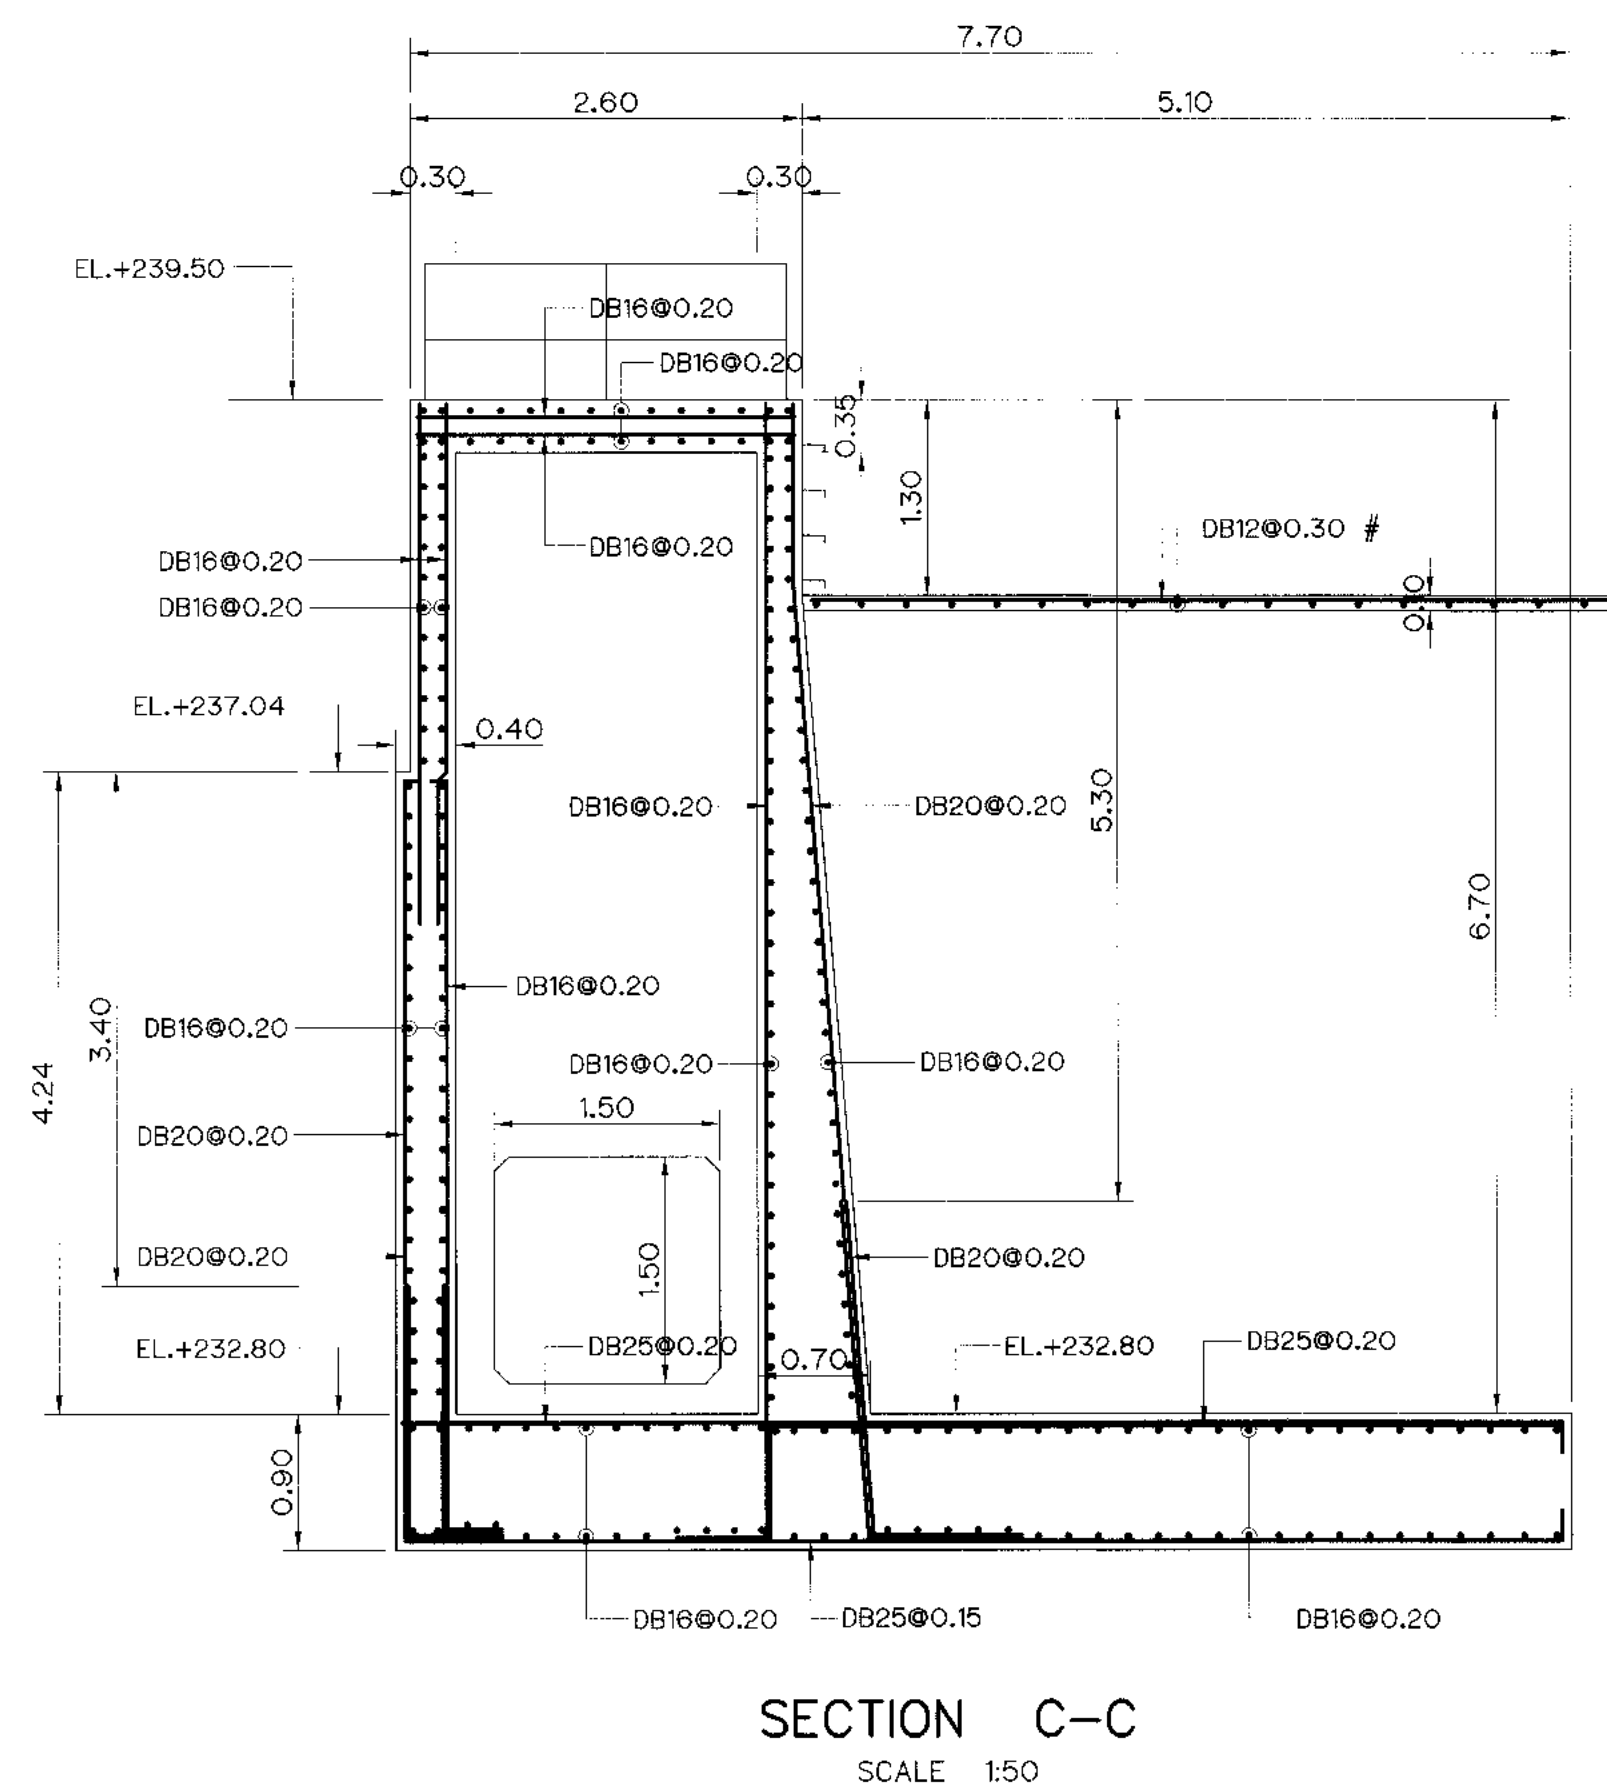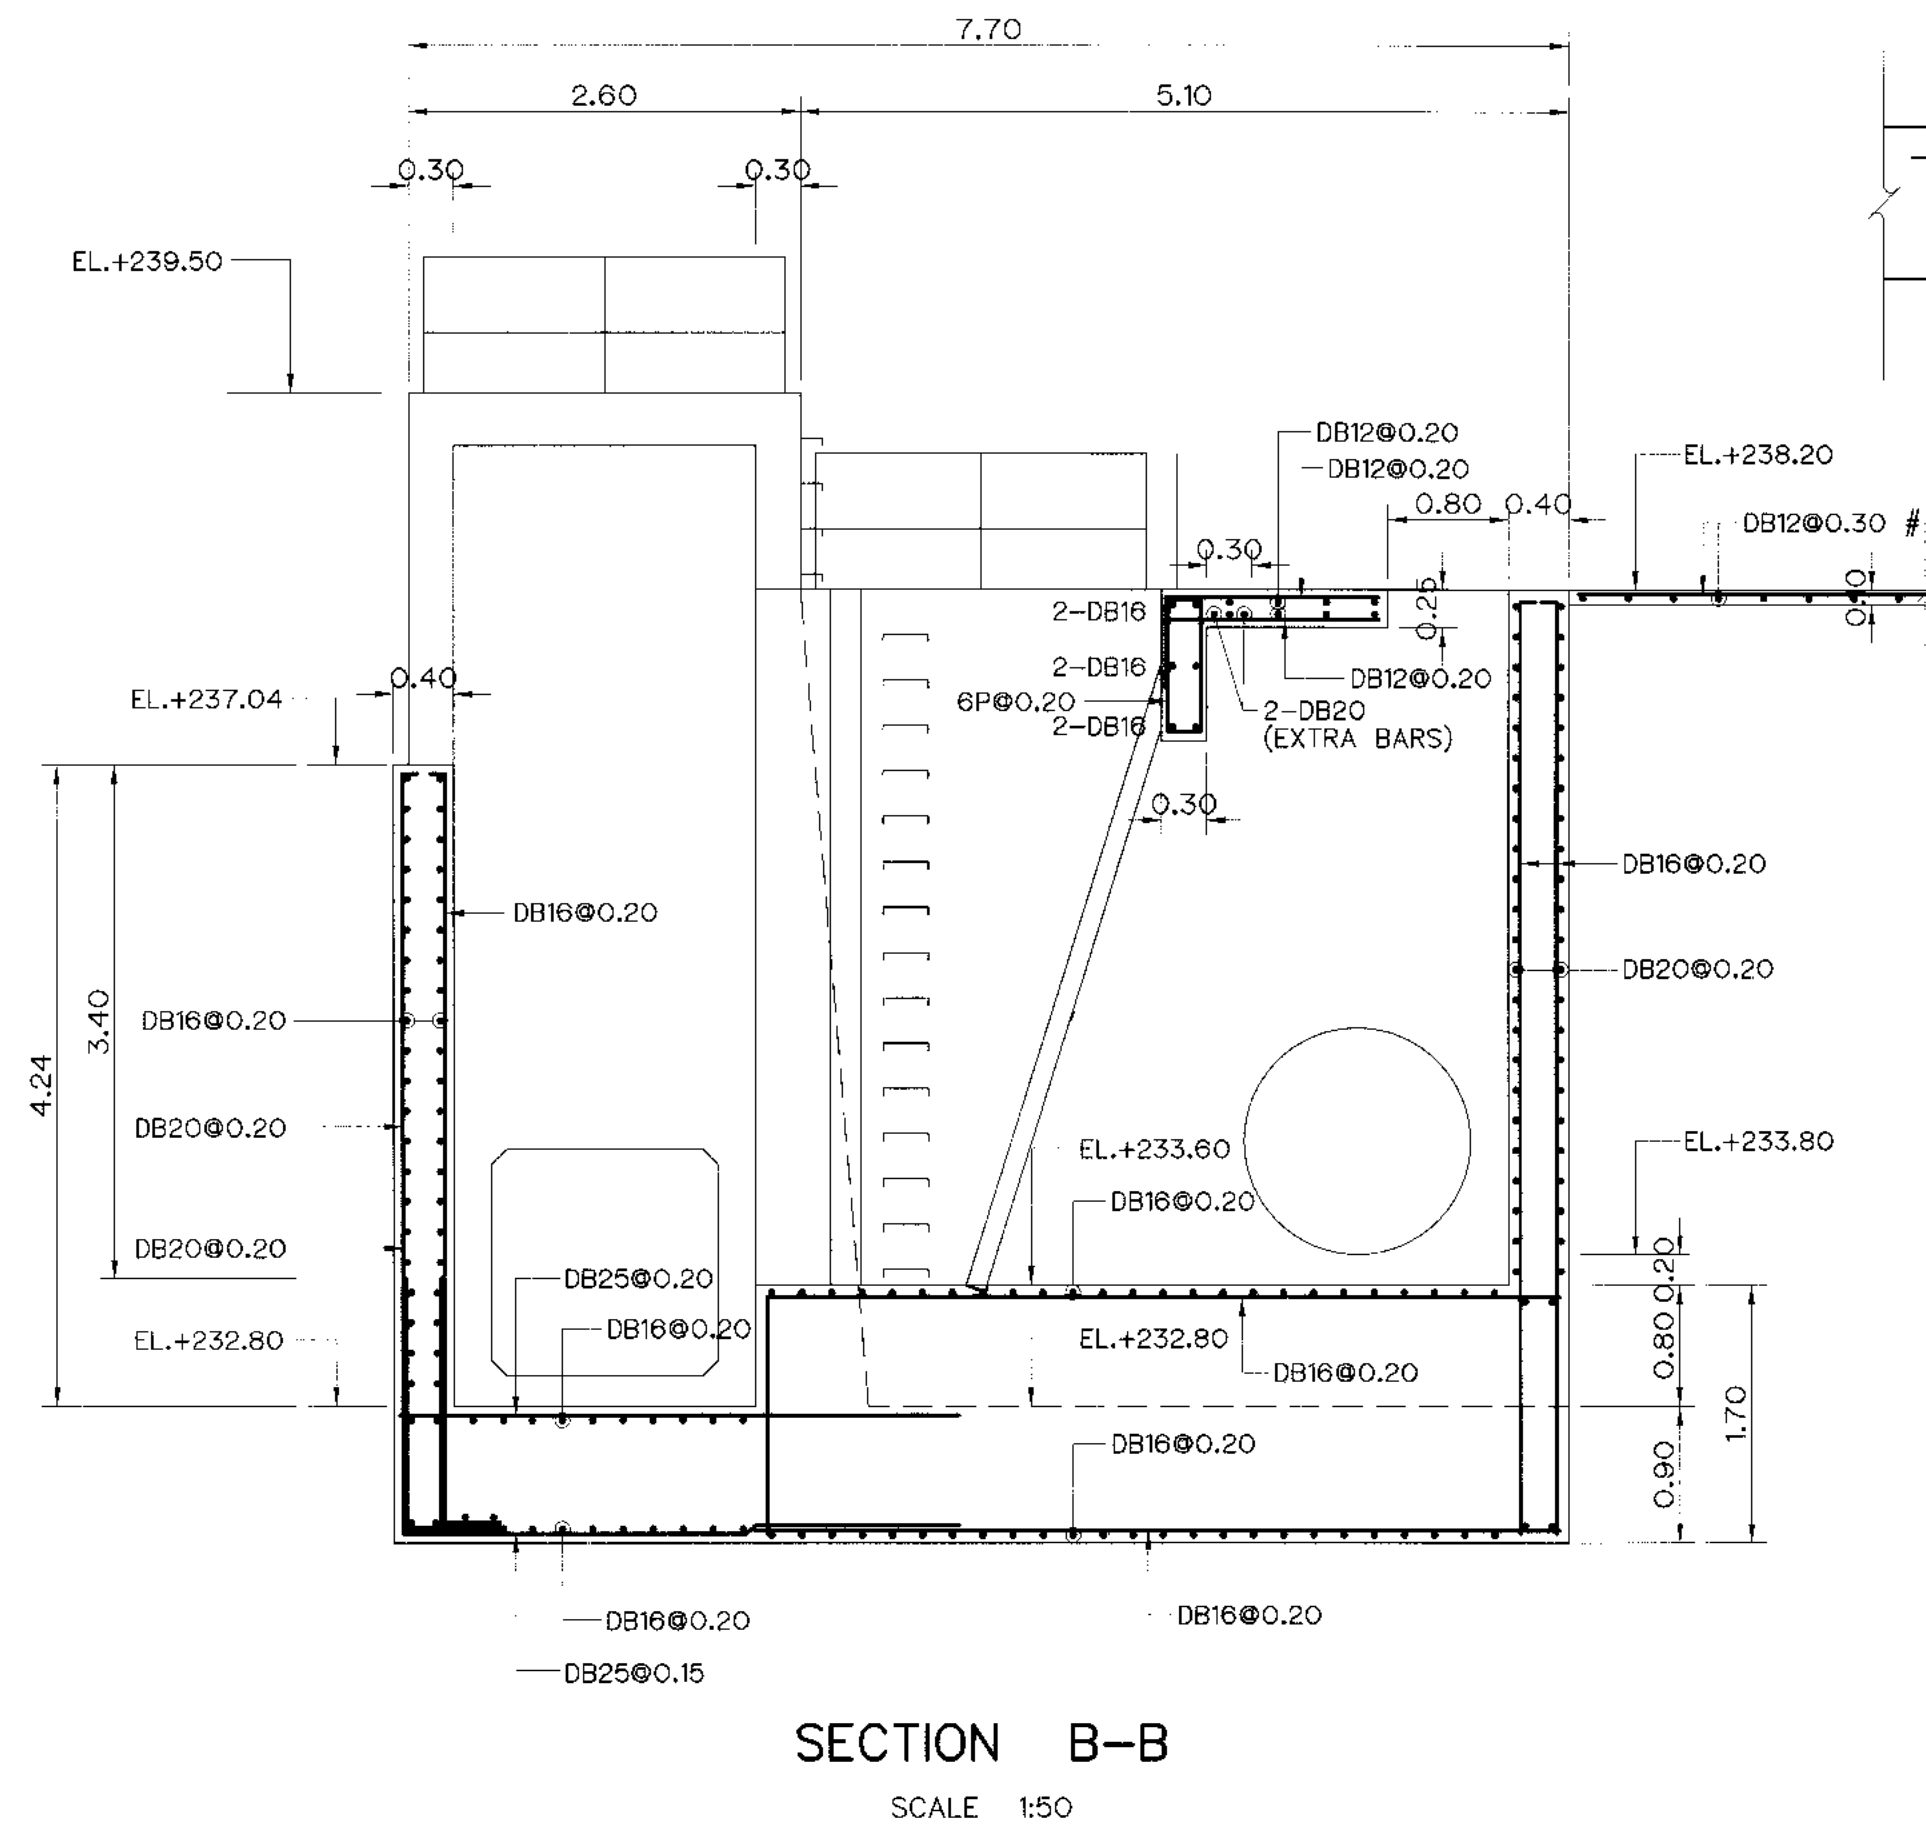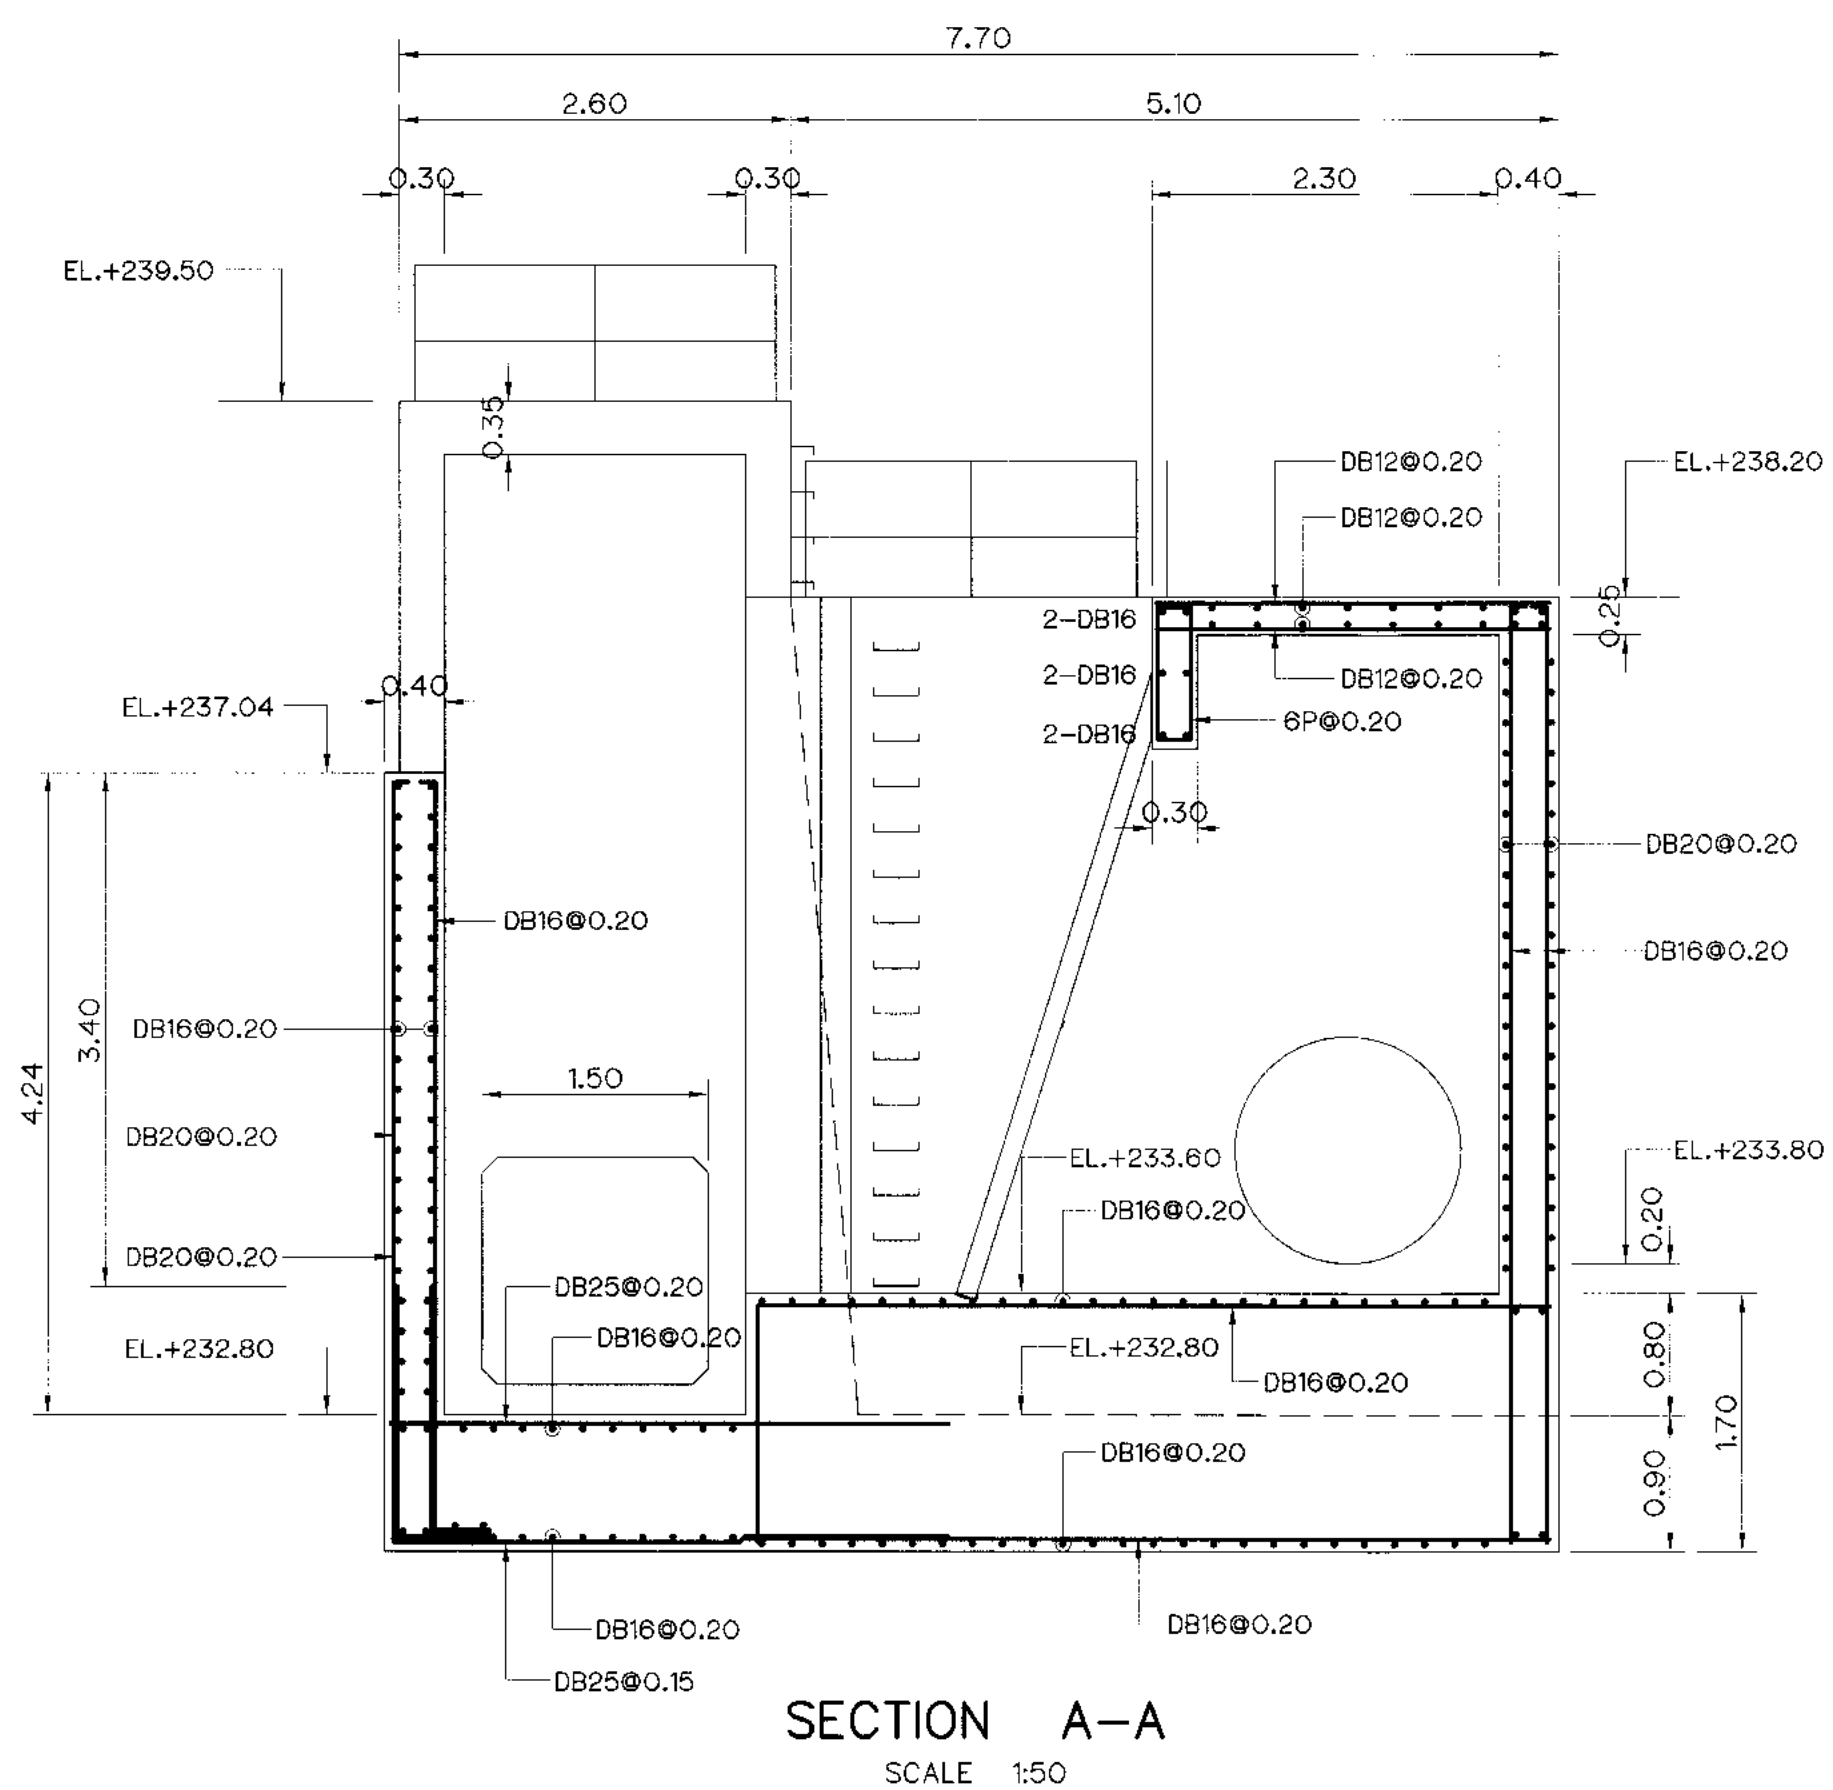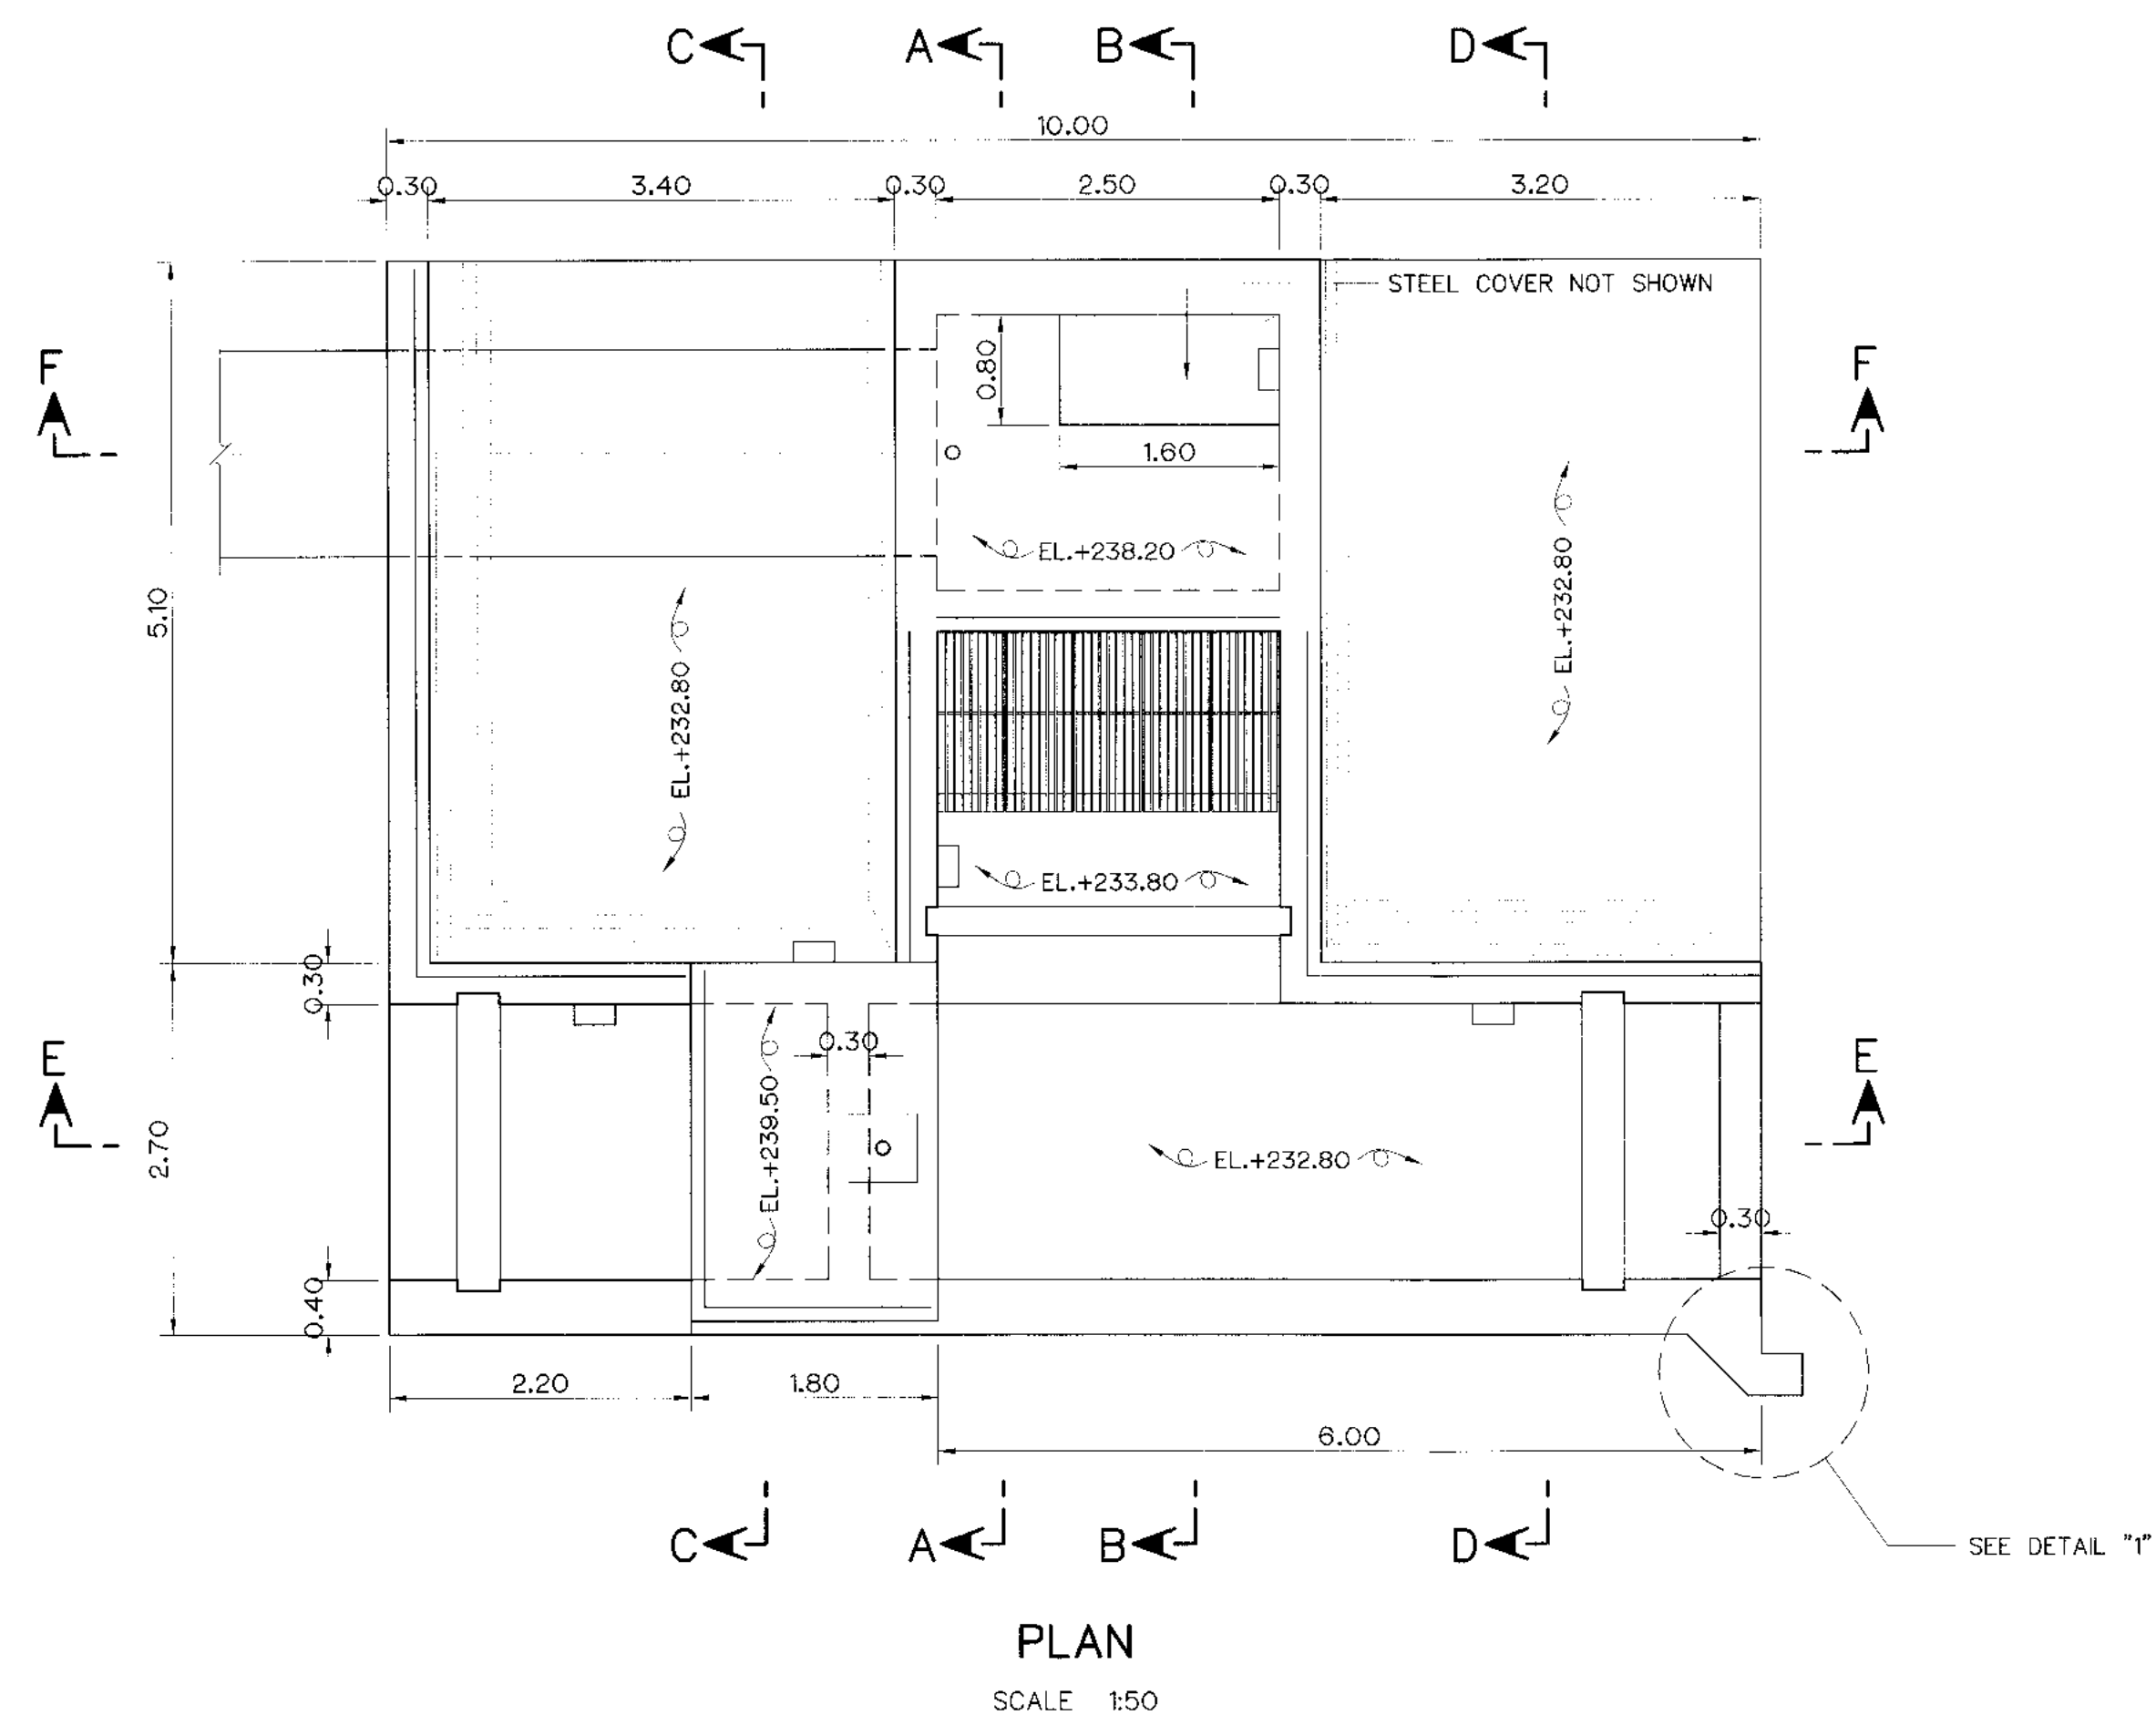


NOTES :

- ALL DIMENSIONS AND ELEVATIONS (M.S.L.) ARE IN METERS, UNLESS OTHERWISE SHOWN.
- SYMBOLS, ABBREVIATIONS AND GENERAL NOTES SEE DWG. NO. KLP-GN-03
- CONCRETE DESIGN BASED ON THE COMPRESSIVE STRENGTH OF 210 KSC, STANDARD CYLINDER $\phi 0.15 \times 0.30$ m. TEST AT AGE 28 DAYS, UNLESS OTHERWISE INDICATED IN SPECIFIC DRAWINGS.
- ULTIMATE TENSILE STRESSES OF REINFORCING STEEL, CONFORM TO THE REQUIREMENT OF THAI INDUSTRIAL STANDARD DESIGNATION SR24 FOR STRUCTURAL GRADE PLAIN ROUND BAR AND SD30 FOR INTERMEDIATE GRADE DEFORMED BAR.


REFERENCE DRAWINGS :

- WEIR : WEIR REHABILITATION GENERAL LAY-OUT KLP-WE-01
- WEIR : INTAKE STRUCTURE REINFORCEMENT DETAILS (SHEET 2/2) KLP-WE-07

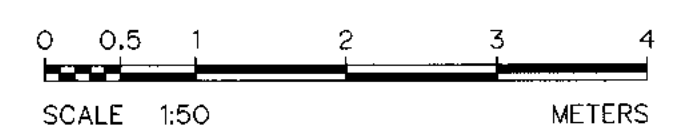


KINGDOM OF THAILAND Department of Alternative Energy Development and Efficiency MINISTRY OF ENERGY	
KLONG LAM PLOK HYDROPOWER PROJECT	
CIVIL WORKS AND TRANSMISSION LINE WEIR : INTAKE STRUCTURE REINFORCEMENT DETAILS (SHEET 1/2)	
DESIGNED <i>[Signature]</i> 11/29/074 07/11/6226	REVIEWED <i>[Signature]</i>
DRAWN <i>[Signature]</i>	SUBMITTED <i>[Signature]</i>
CHECKED <i>[Signature]</i> 07/11/6226	RECOMMENDED <i>[Signature]</i>
APPROVED <i>[Signature]</i>	APPROVED <i>[Signature]</i>
PROJECT MANAGER <i>[Signature]</i> 08/03/2559	DRAWING NO. KLP-WE-06
DATE	SHEET NO. 15 OF 110


3				
2				
1				
NO.	DATE	REVISIONS	CHECKED	APPROVED

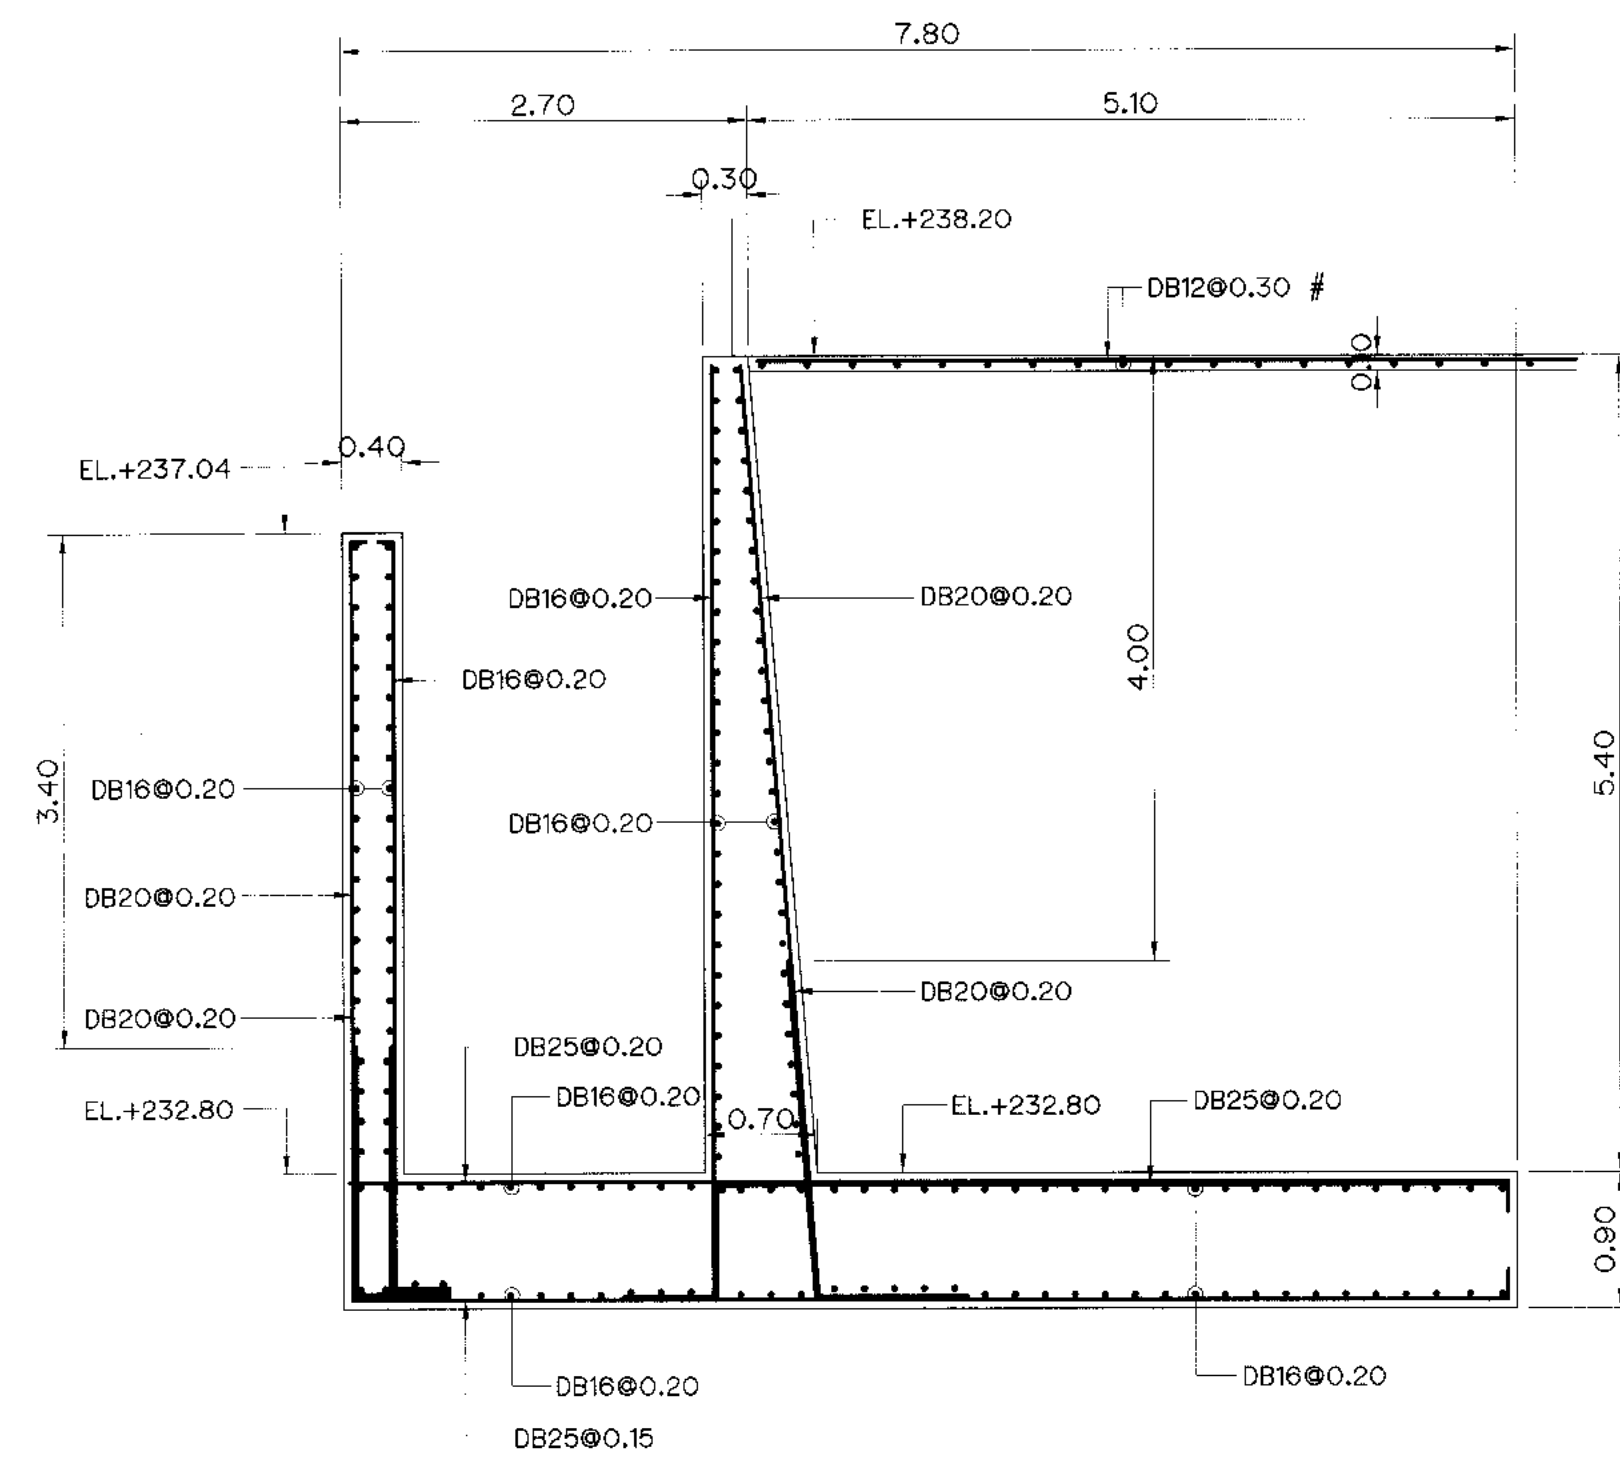


SECTION D-D
SCALE 1:50

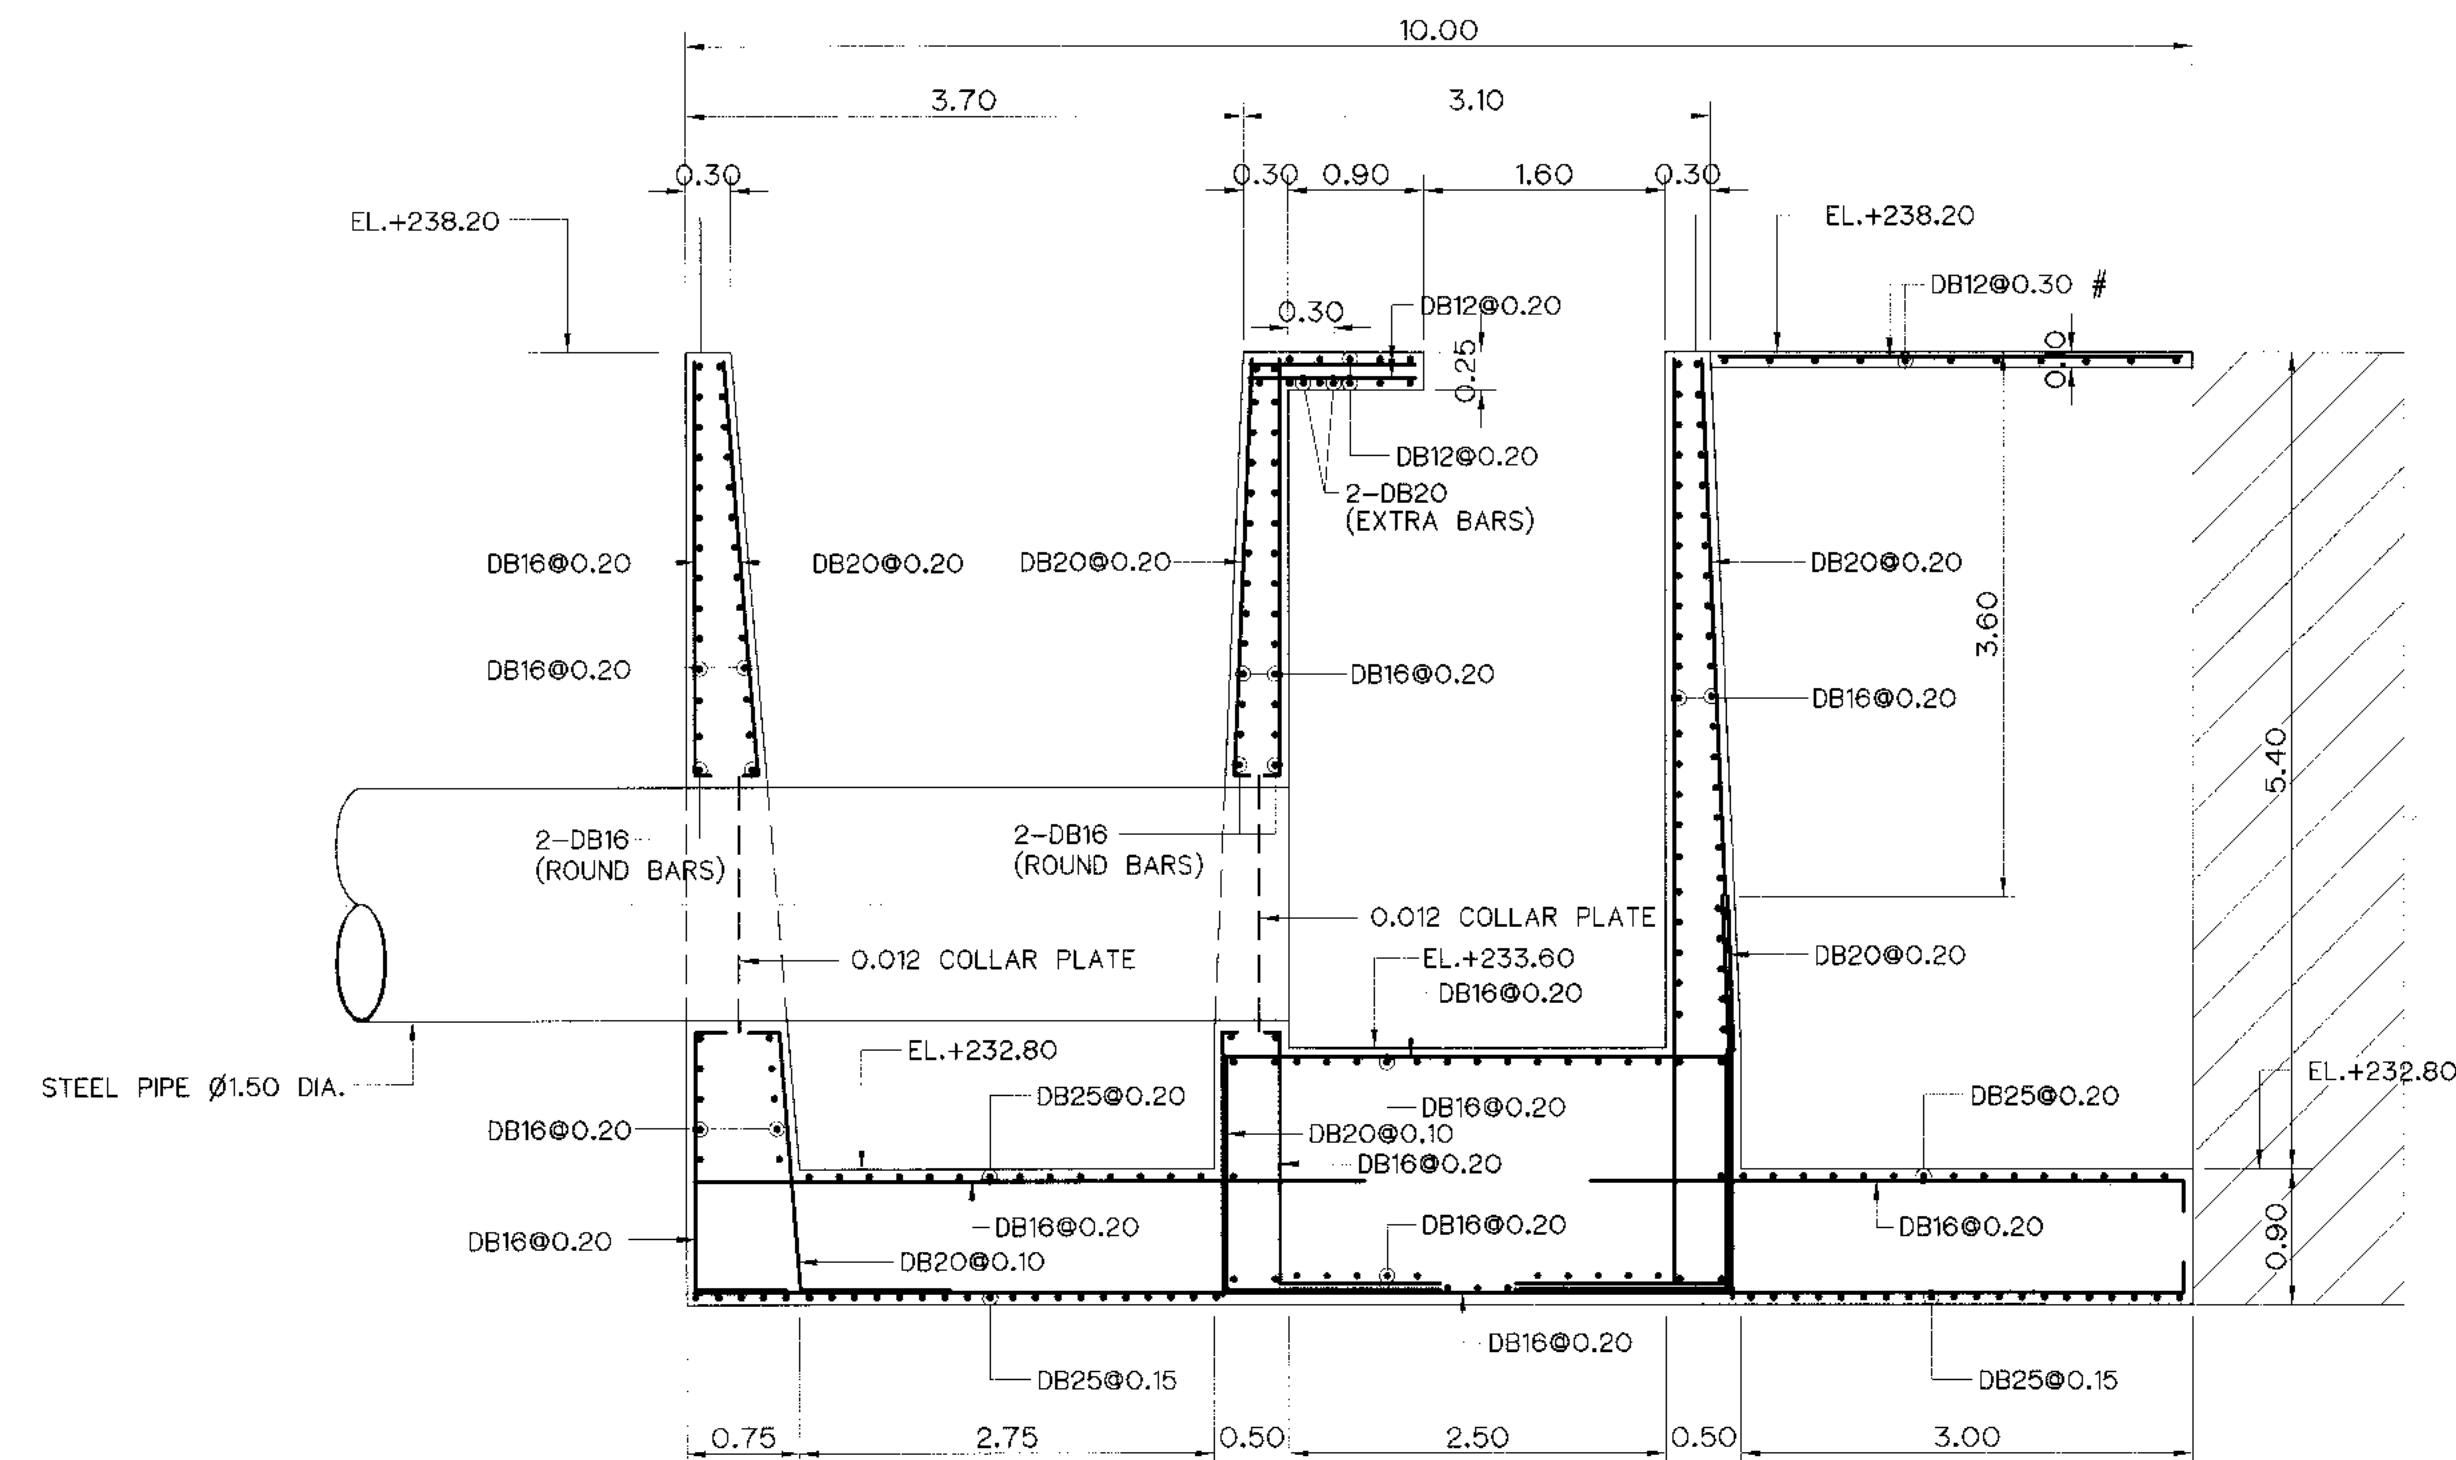

SECTION F-F
SCALE 1:50

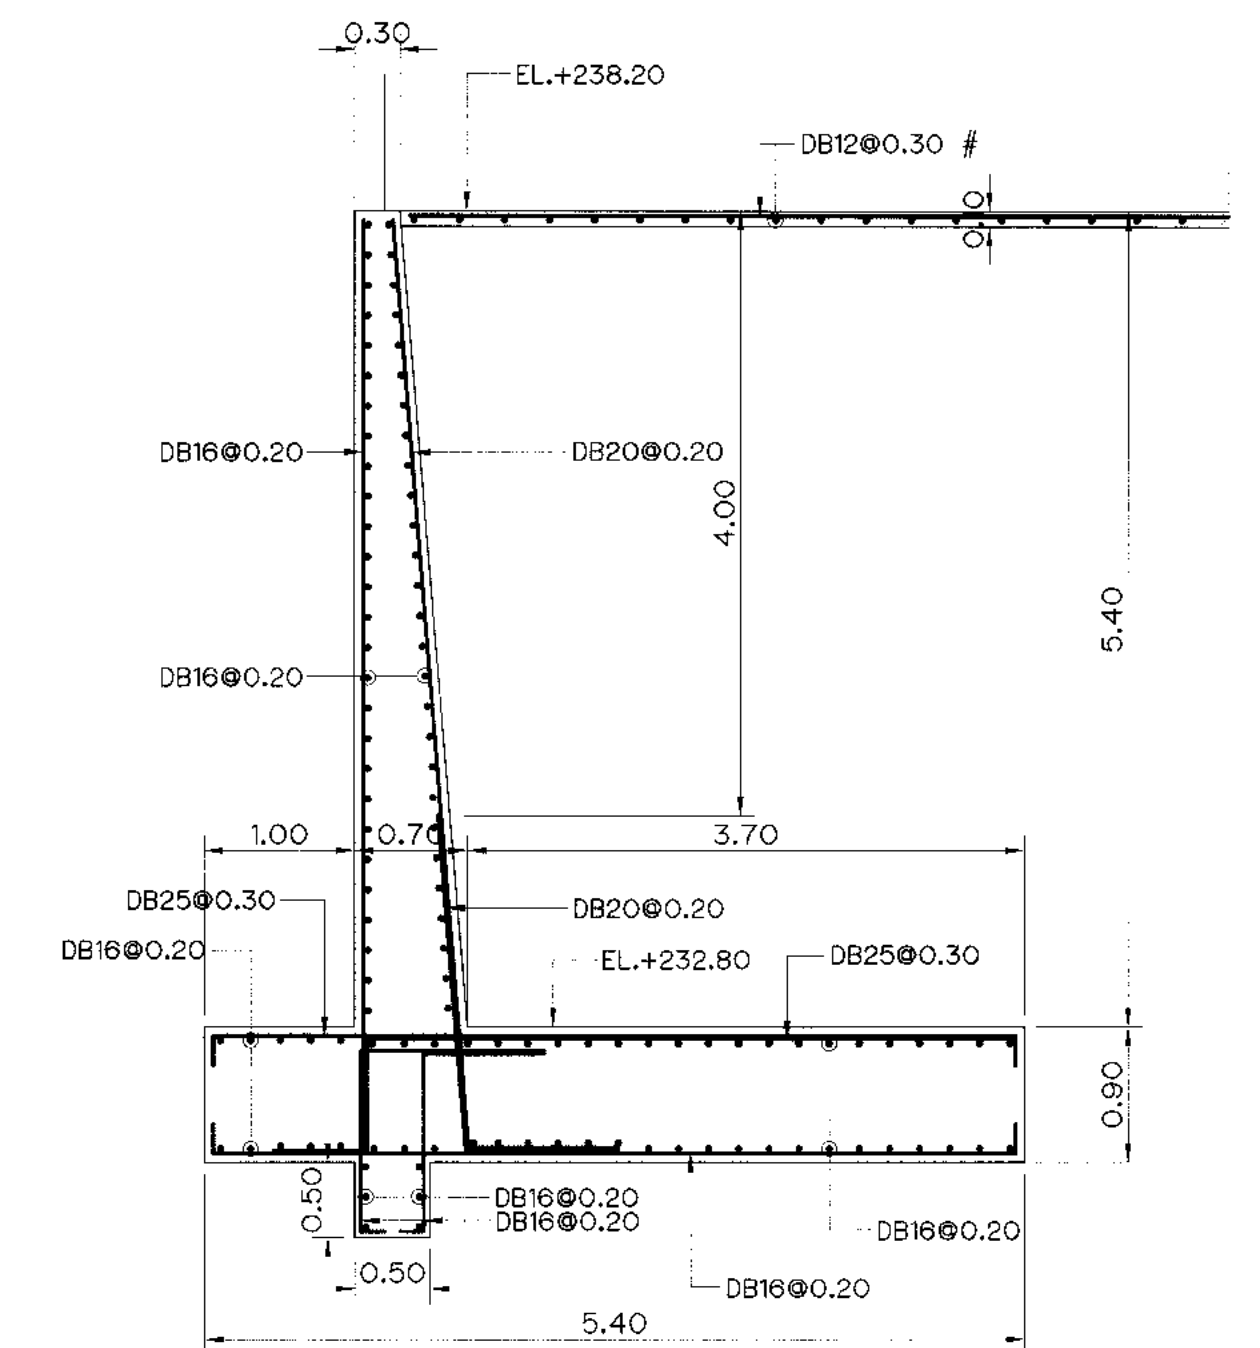

RETAINING WALL
SCALE 1:50

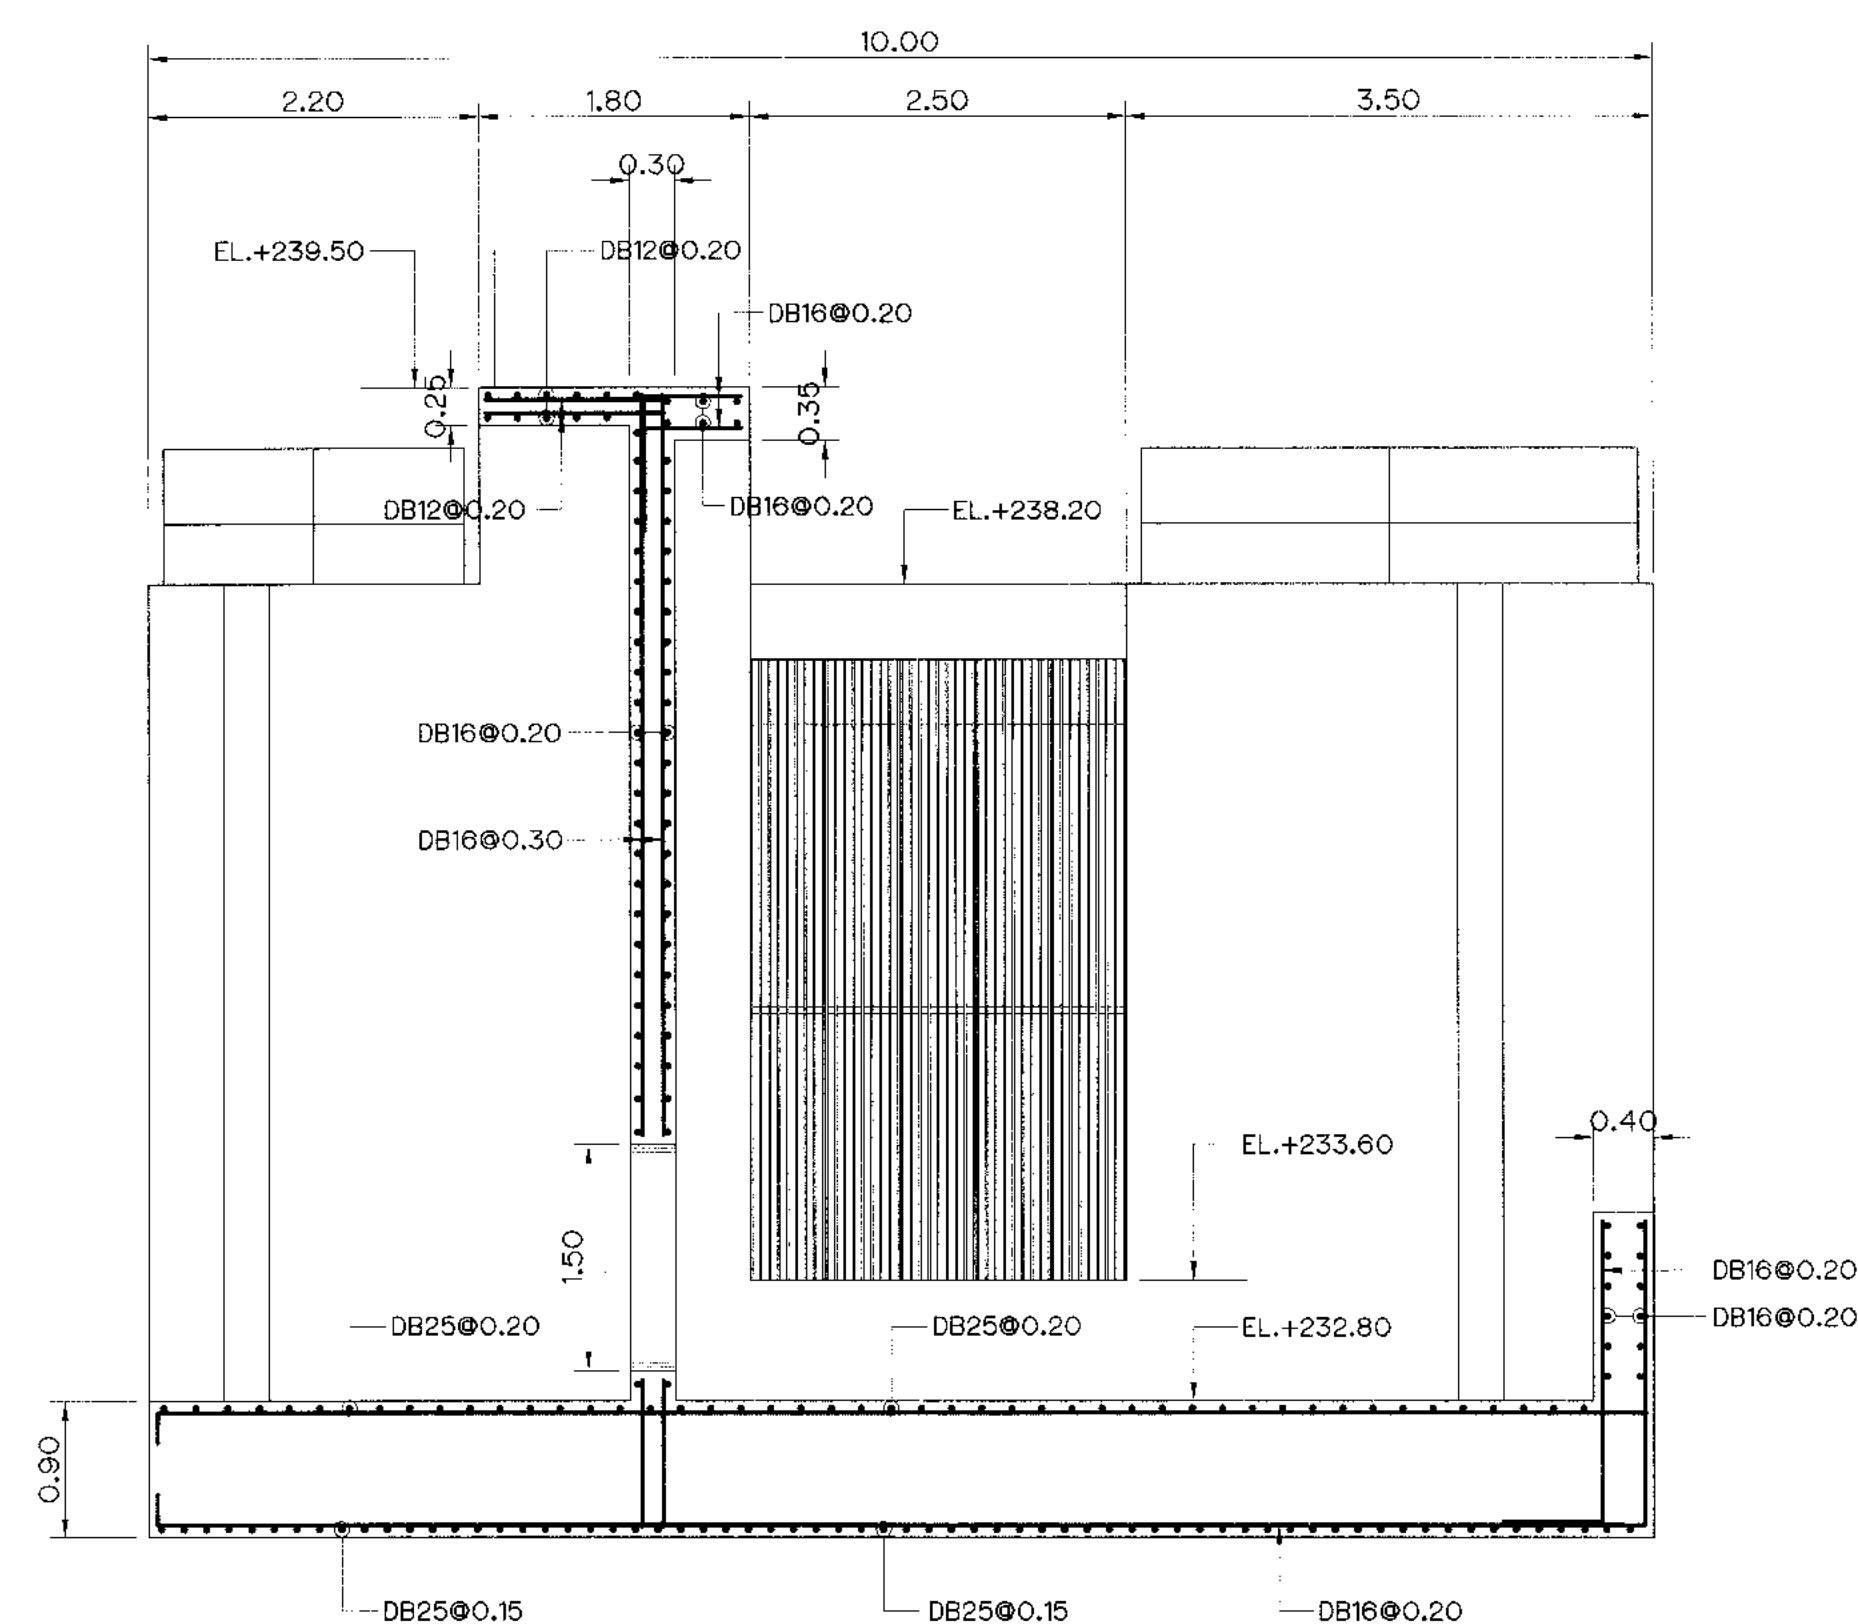


SECTION E-E
SCALE 1:50

NOTES :


- ALL DIMENSIONS AND ELEVATIONS (M.S.L.) ARE IN METERS, UNLESS OTHERWISE SHOWN.
- SYMBOLS, ABBREVIATIONS AND GENERAL NOTES SEE DWG. NO. KLP-GN-03
- CONCRETE DESIGN BASED ON THE COMPRESSIVE STRENGTH OF 210 KSC, STANDARD CYLINDER $\phi 0.15 \times 0.30$ m. TEST AT AGE 28 DAYS, UNLESS OTHERWISE INDICATED IN SPECIFIC DRAWINGS.
- ULTIMATE TENSILE STRESSES OF REINFORCING STEEL, CONFORM TO THE REQUIREMENT OF THAI INDUSTRIAL STANDARD DESIGNATION SR24 FOR STRUCTURAL GRADE PLAIN ROUND BAR AND SD30 FOR INTERMEDIATE GRADE DEFORMED BAR.

REFERENCE DRAWINGS :

- WEIR : INTAKE STRUCTURE REINFORCEMENT DETAILS (SHEET 1/2) KLP-WE-06

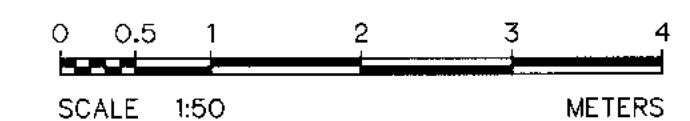



KINGDOM OF THAILAND Department of Alternative Energy Development and Efficiency MINISTRY OF ENERGY	
KLONG LAM PLOK HYDROPOWER PROJECT	
CIVIL WORKS AND TRANSMISSION LINE WEIR : INTAKE STRUCTURE REINFORCEMENT DETAILS (SHEET 2/2)	
P&C MANAGEMENT CO.,LTD. DESIGNED: JML29074 DRAWN: JML8226 CHECKED: JML8226 PROJECT MANAGER: 08/03/2559	MINISTRY OF ENERGY REVIEWED: JML8226 SUBMITTED: JML8226 RECOMMENDED: JML8226 APPROVED: JML8226 DRAWING NO. KLP-WE-07 SHEET NO. 16 OF 110

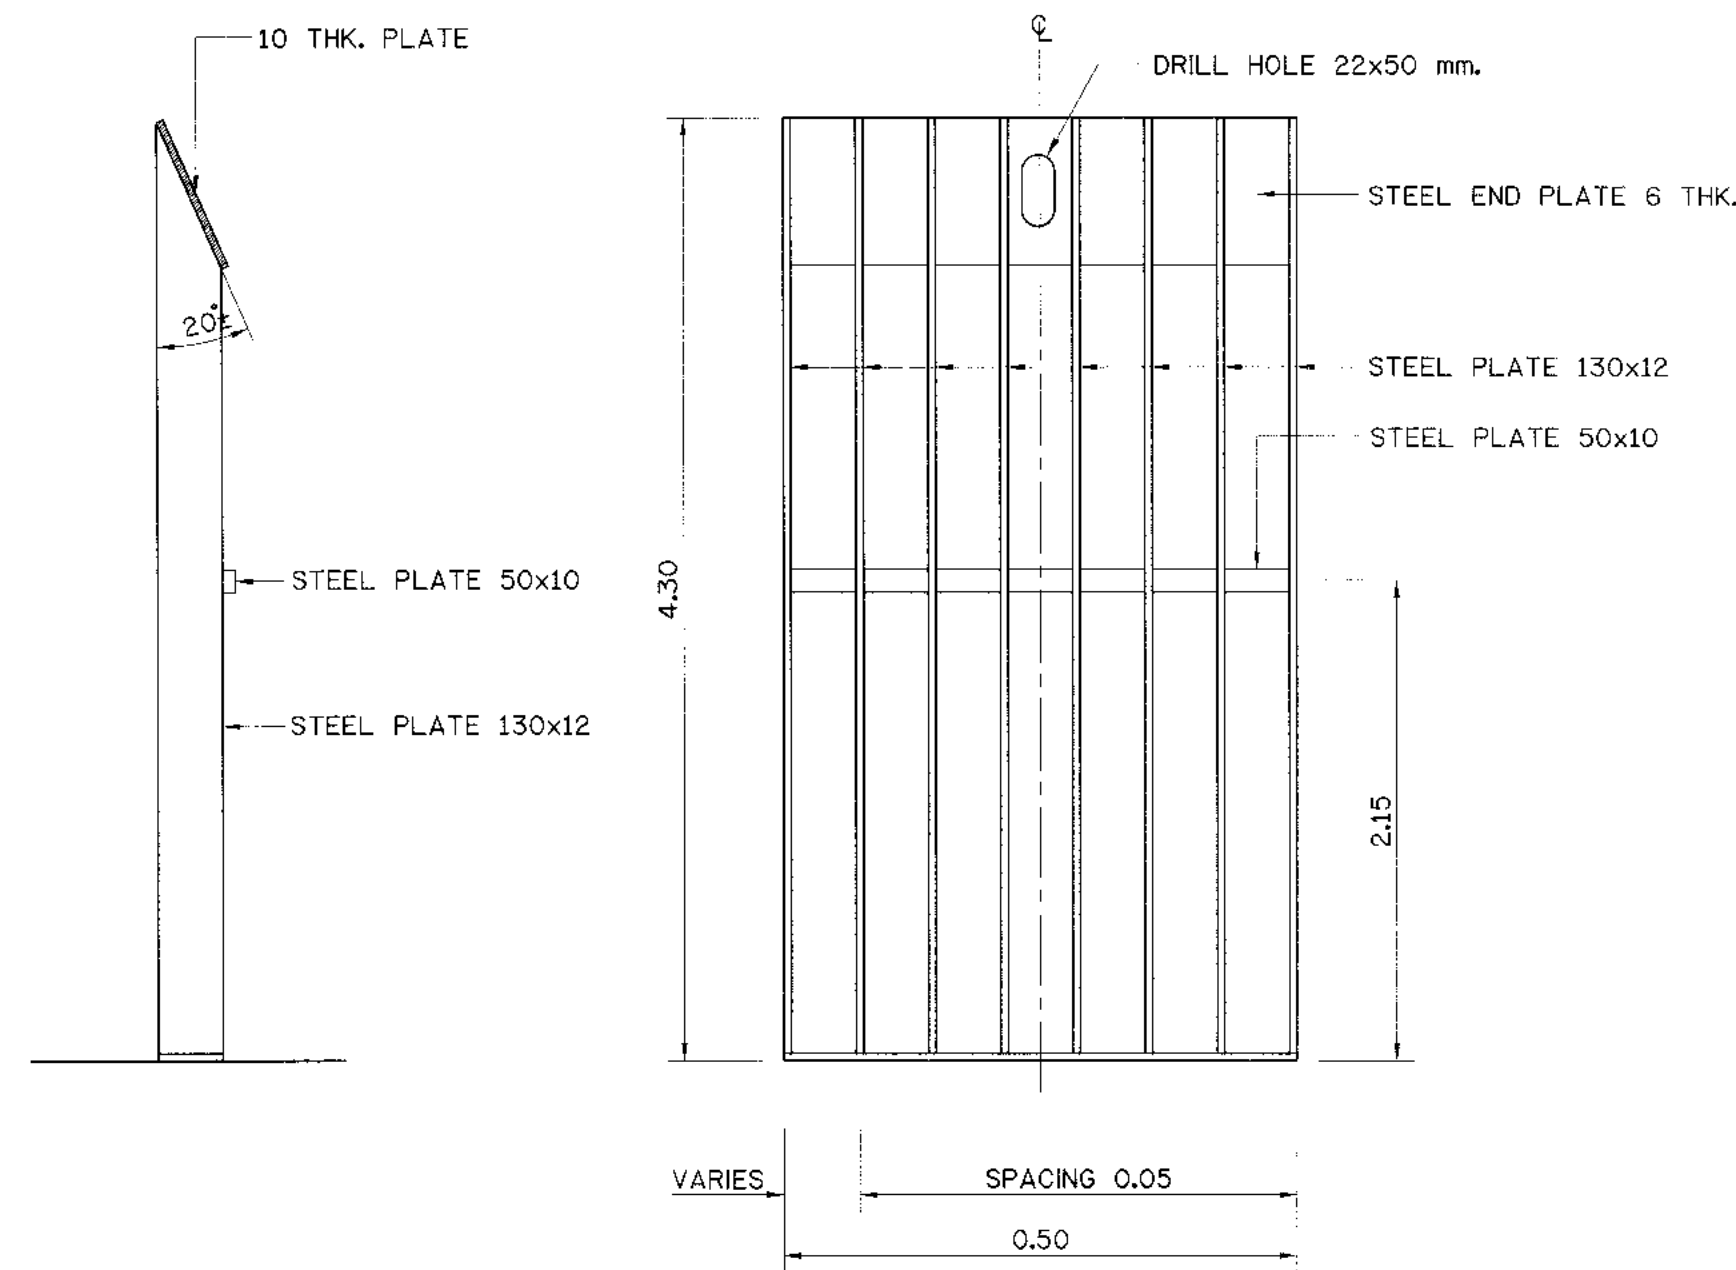



TRASHRACK DETAILS
NOT TO SCALE

Ø2" GALVANIZED STEEL
Ø15 mm.DRILL HOLE


GALVANIZED STEEL
PLATE 10 mm.THK.

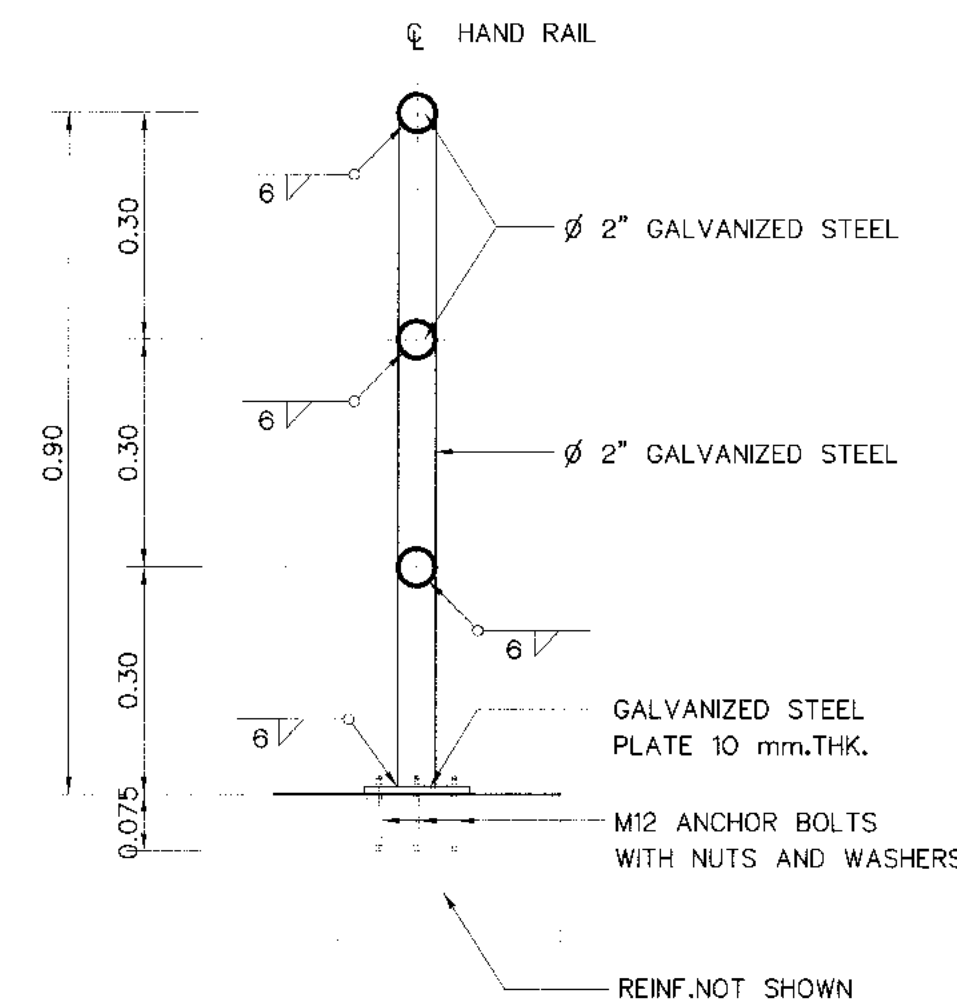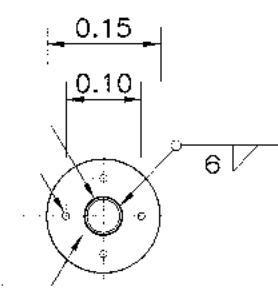


DETAIL OF HANDRAIL
SCALE 1:20

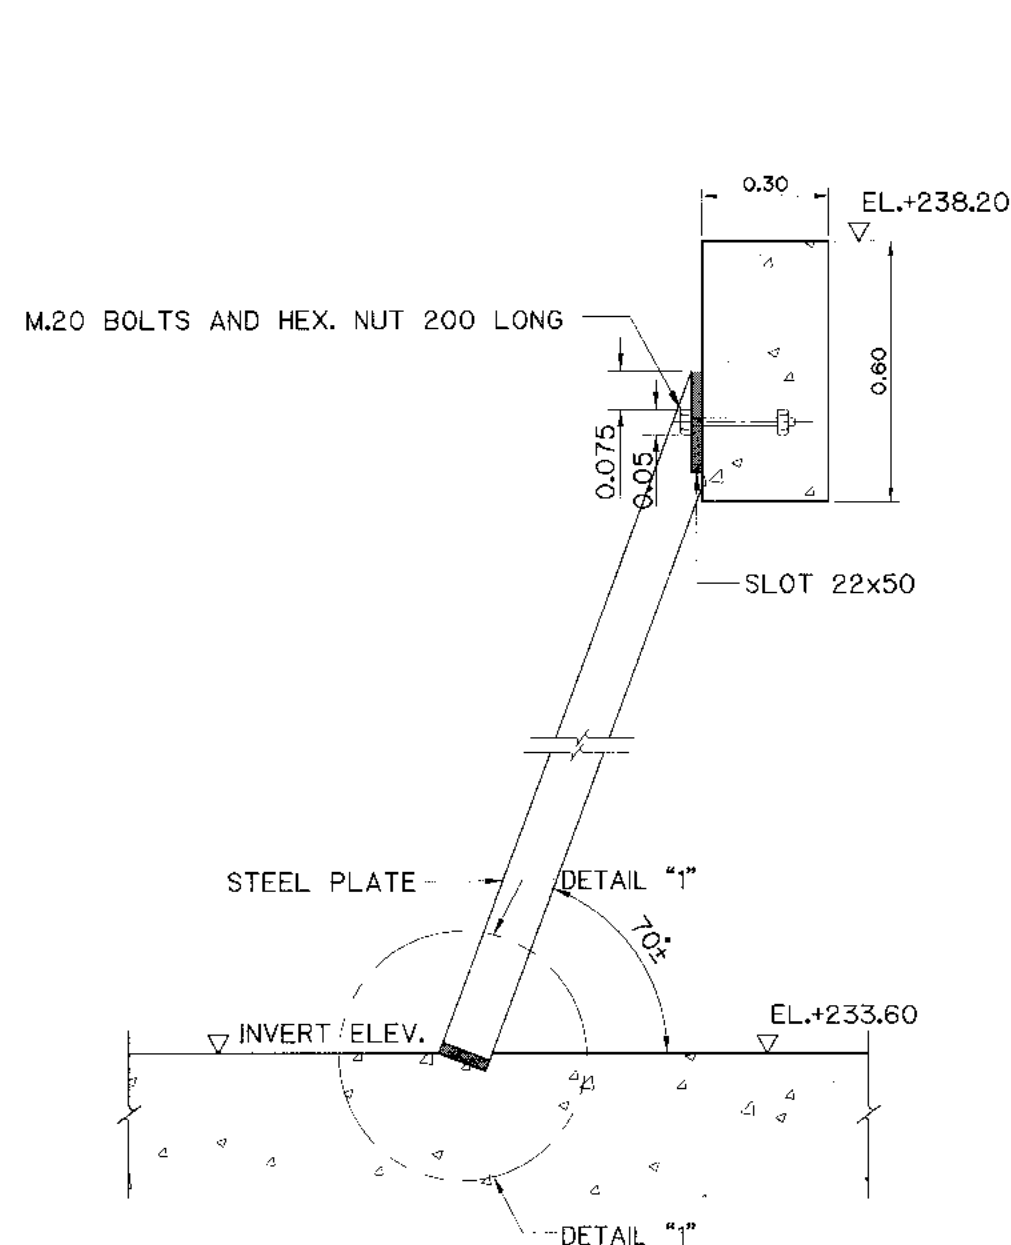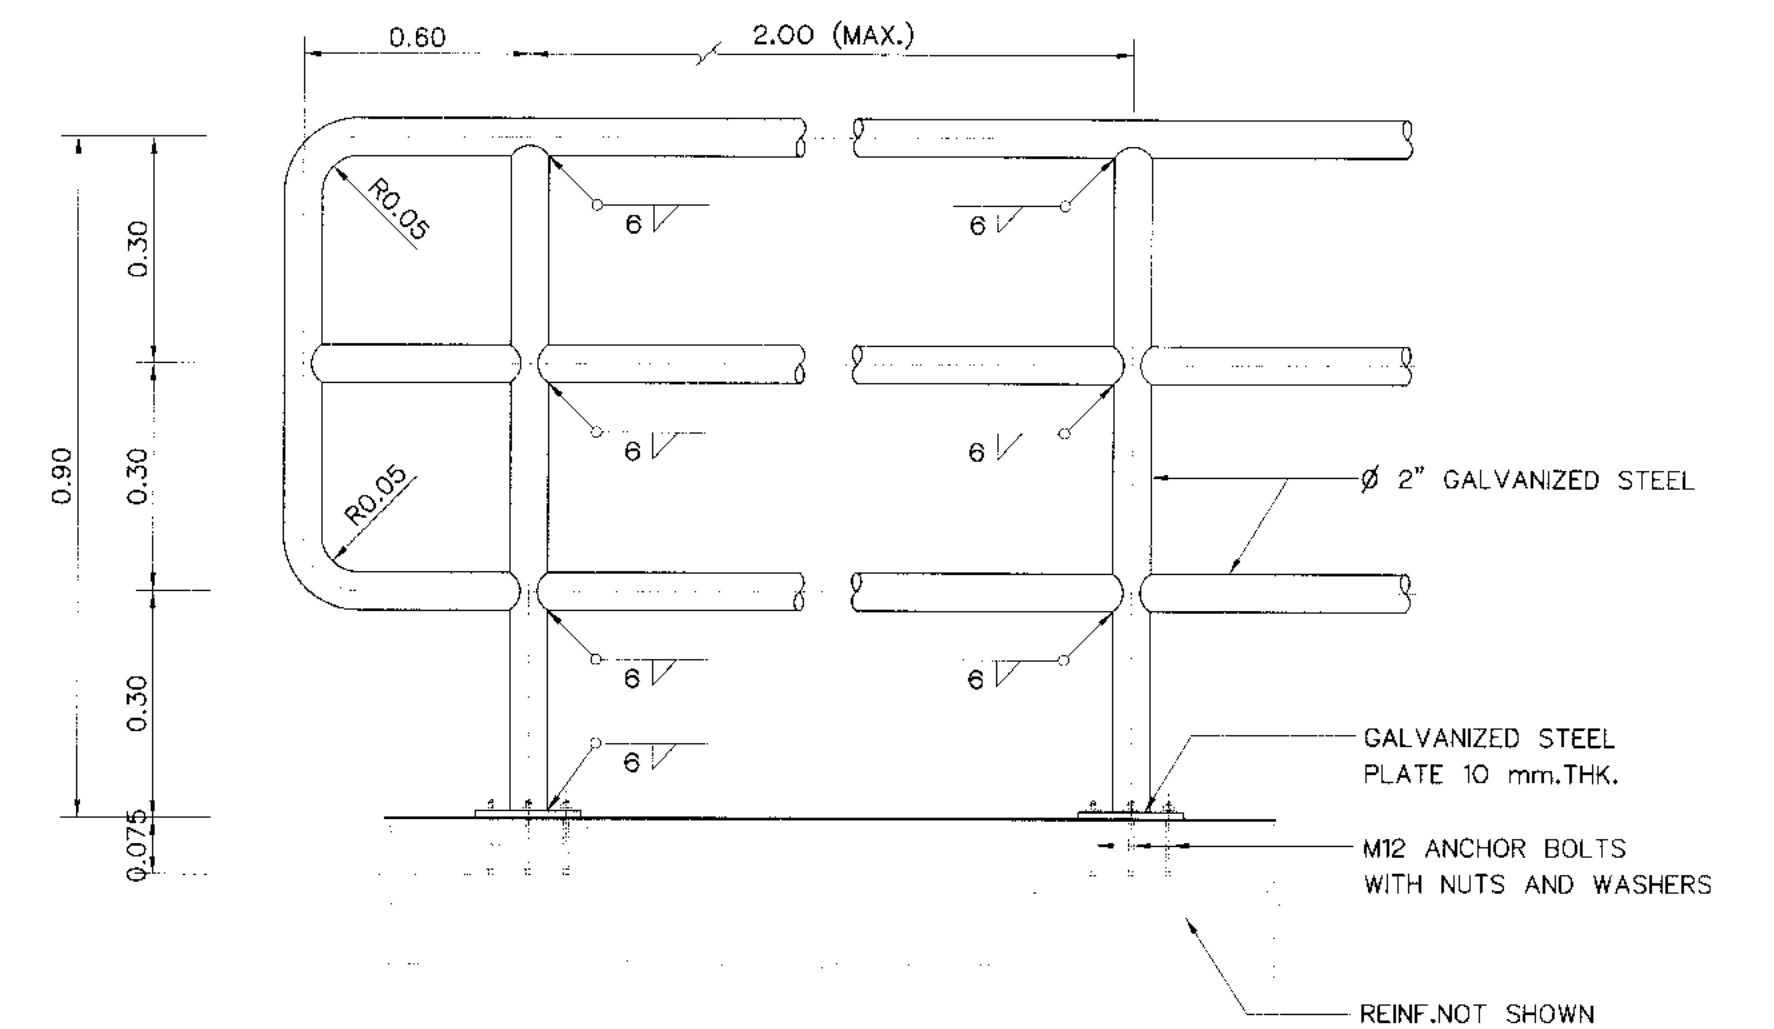


TRASHRACK INSTALLATION
NOT TO SCALE

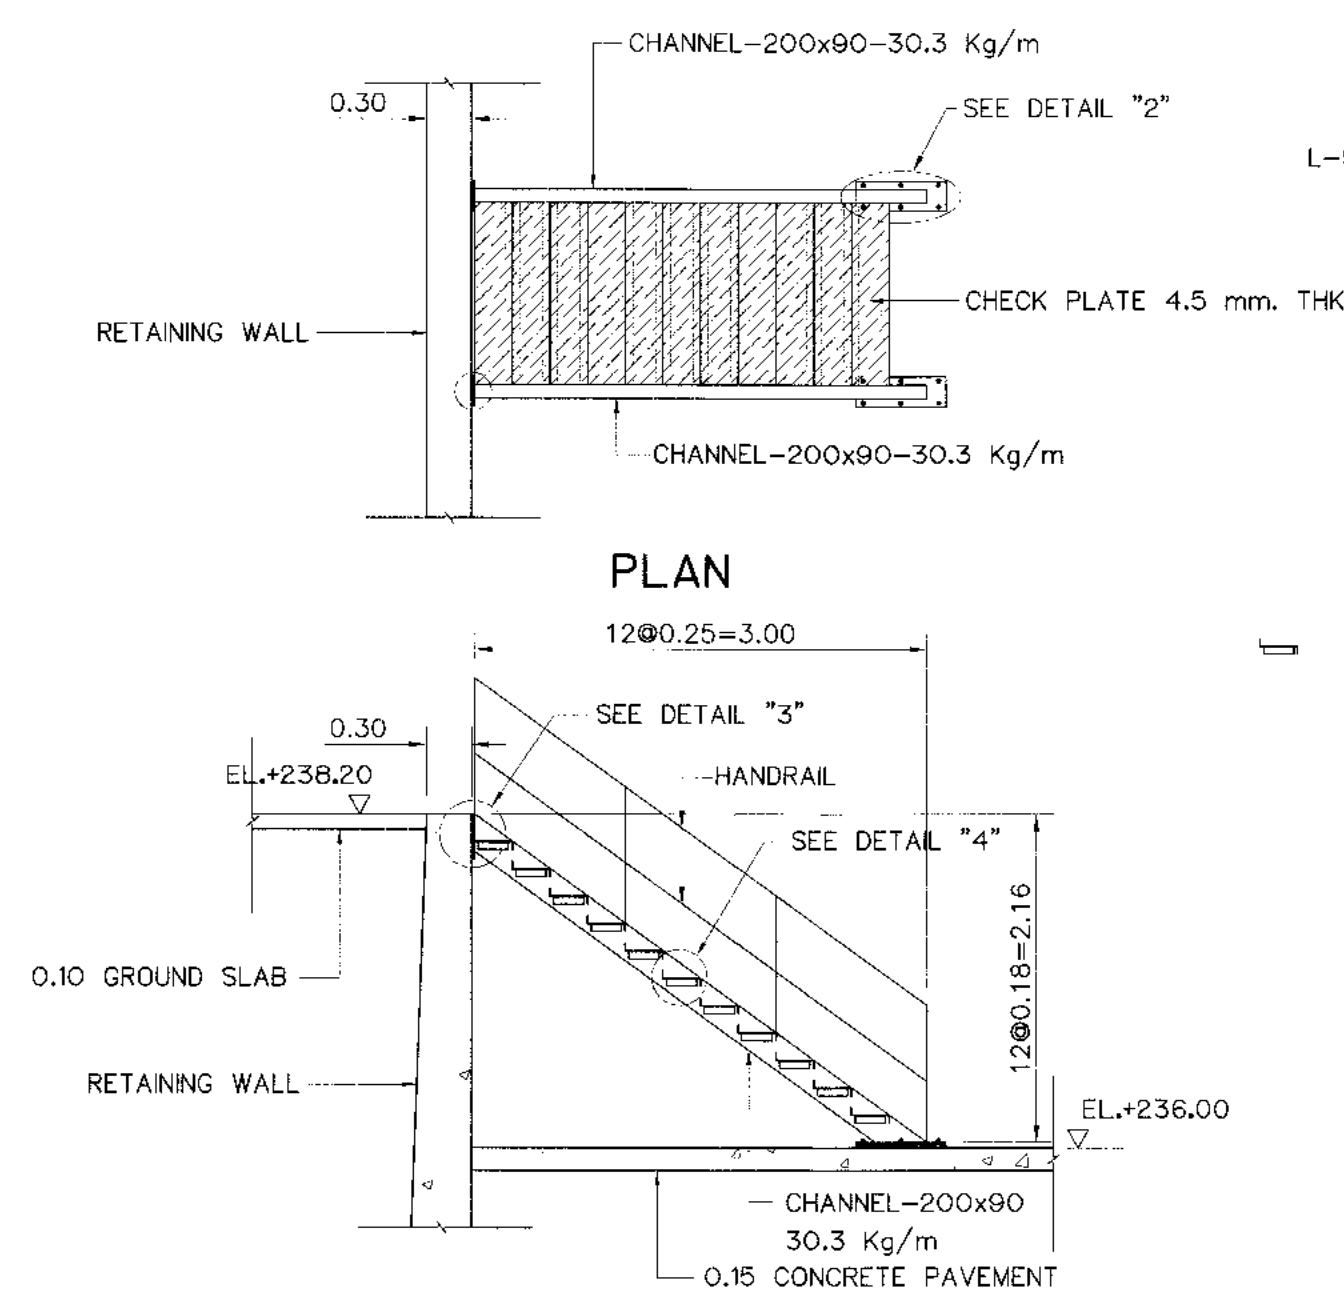


SECTION
NOT TO SCALE

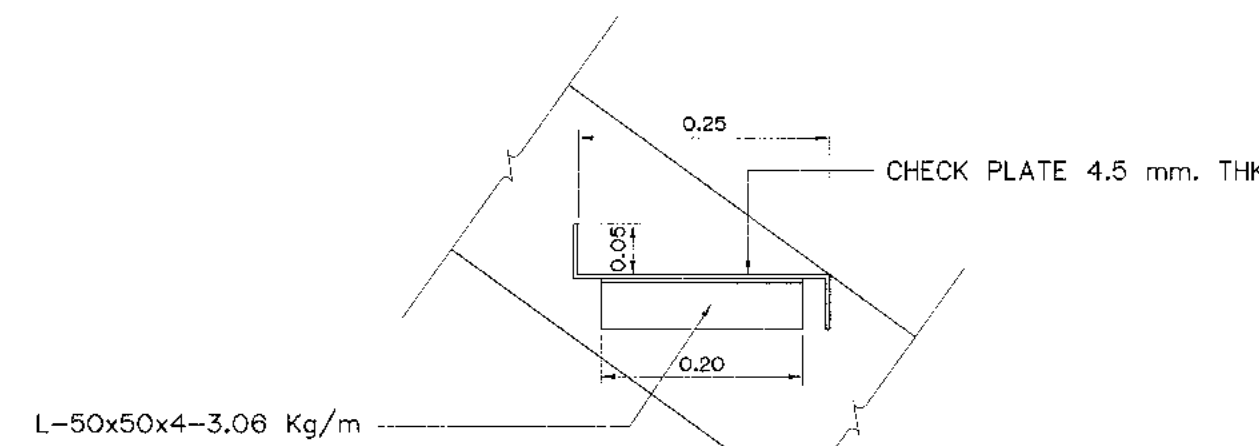


DETAIL "4"
SCALE 1:7.5

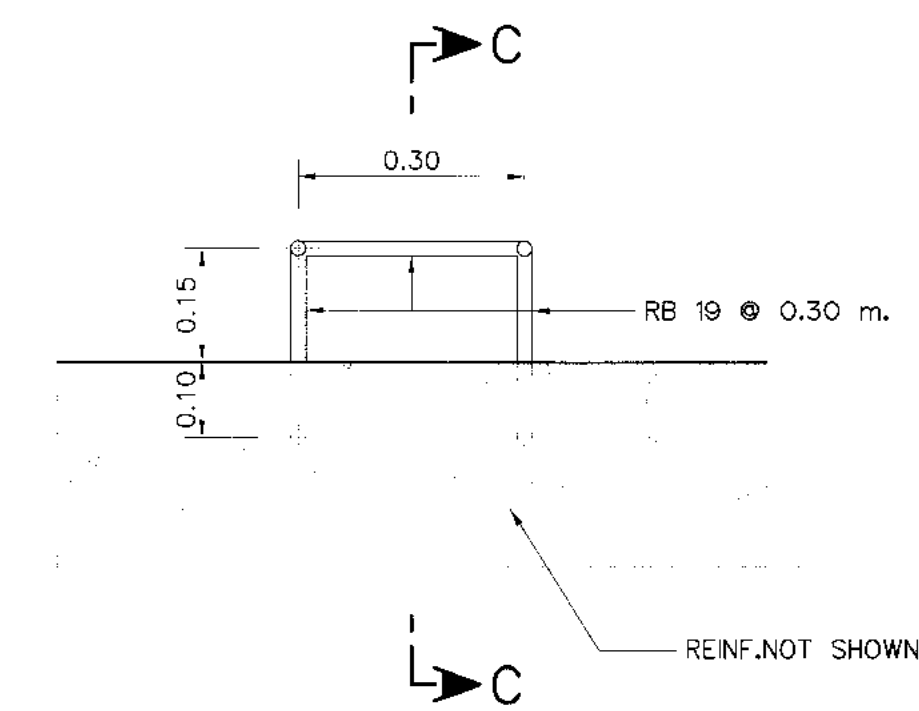


DETAIL OF LADDER RUNG
SCALE 1:20

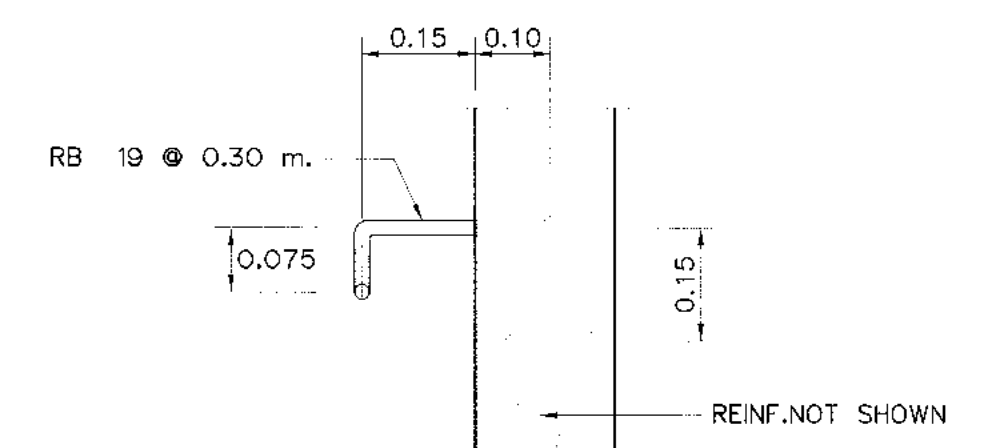



SECTION C - C
SCALE 1:20

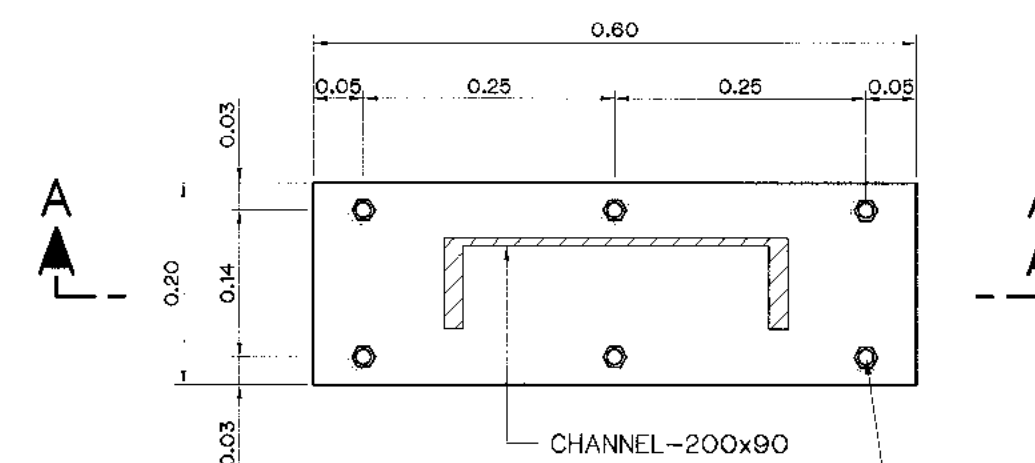


DETAIL "2"
NOT TO SCALE

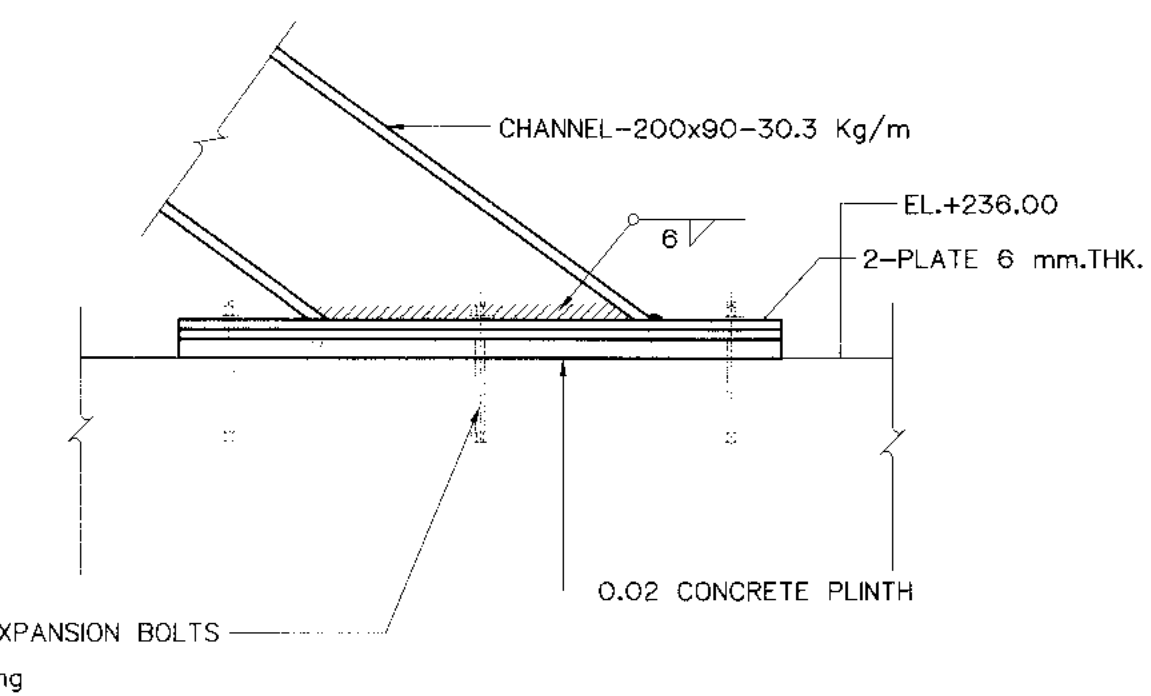


SECTION A-A
NOT TO SCALE

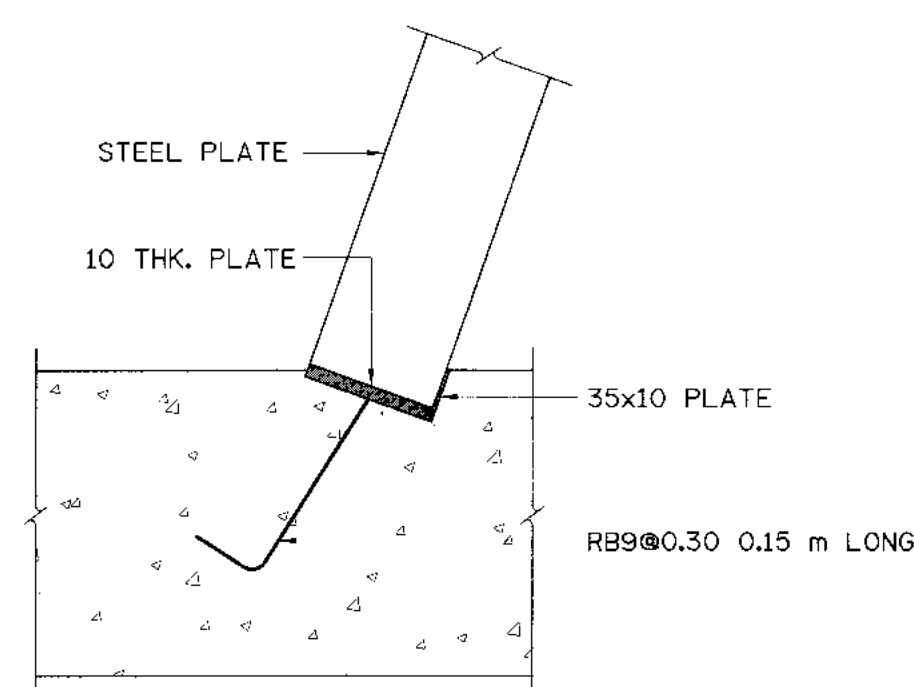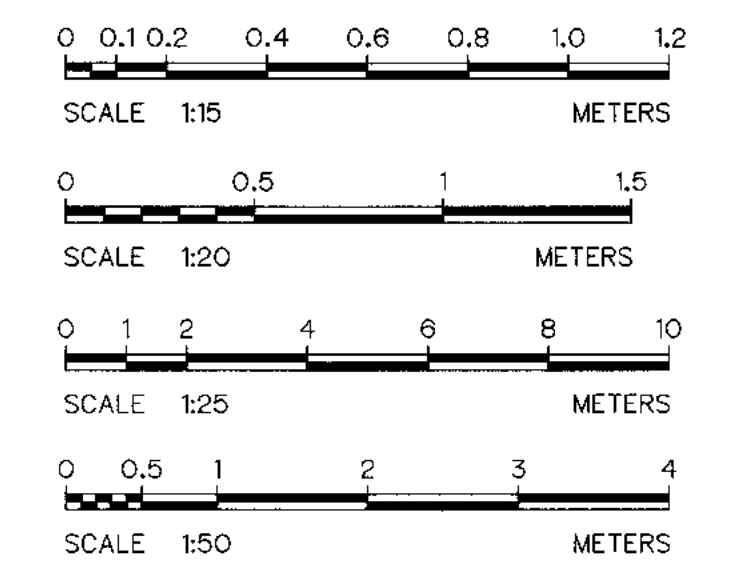

DETAIL "1"
NOT TO SCALE

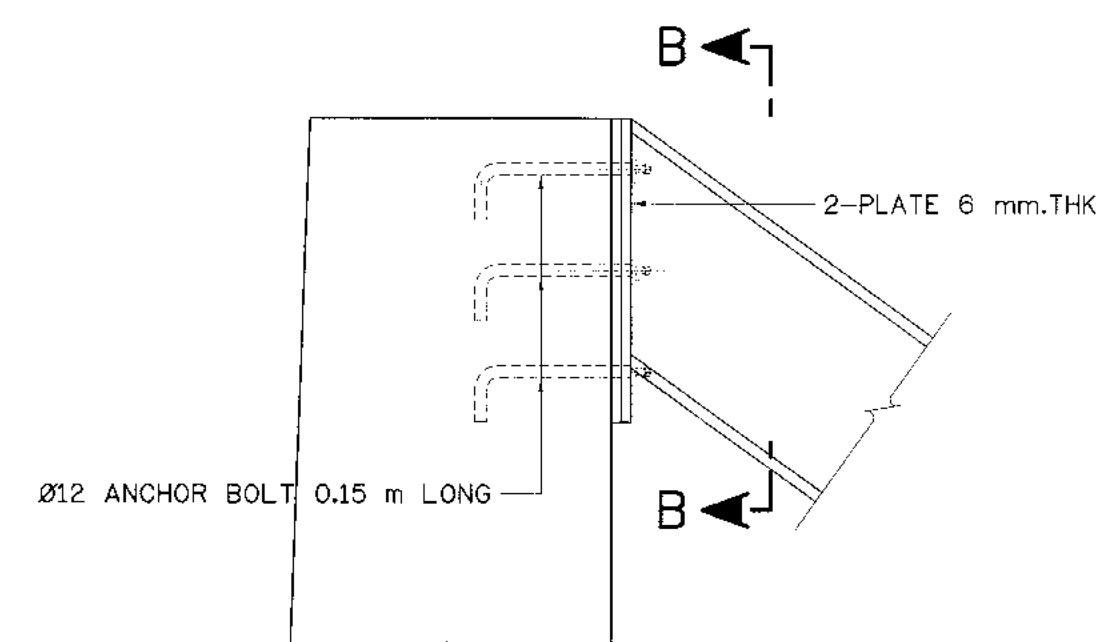

DETAIL "3"
NOT TO SCALE

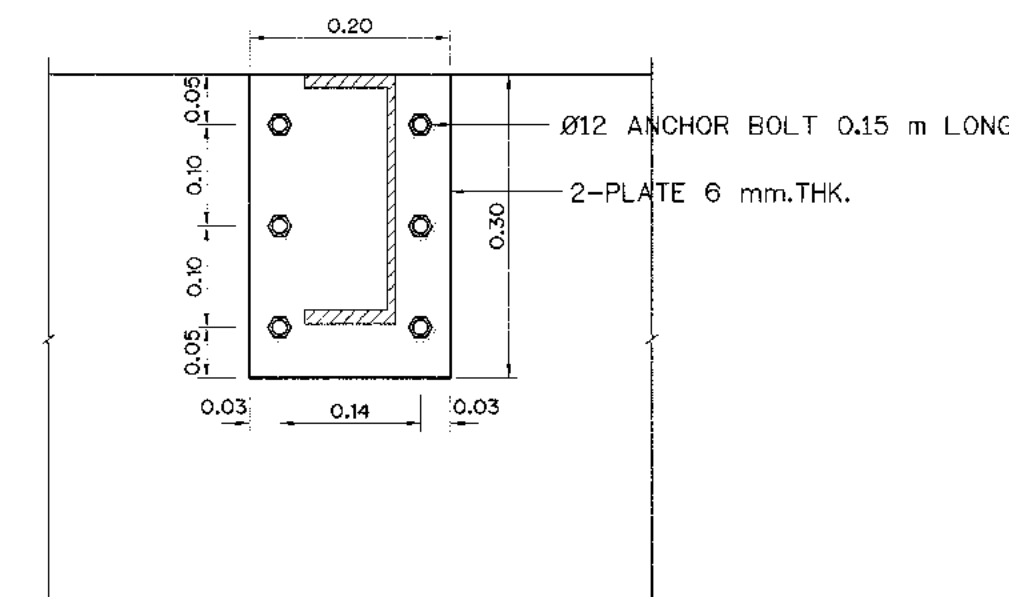


SECTION B-B
NOT TO SCALE

NOTES :


1. ALL DIMENSIONS AND ELEVATIONS ARE IN METER, UNLESS OTHERWISE SHOWN
2. FOR GENERAL NOTES SEE DWG. NO KLP-GN-03
3. WELDING CONNECTION USE 6 mm., UNLESS OTHERWISE SHOWN

3				
2				
1				
NO.	DATE	REVISIONS	CHECKED	APPROVED


KINGDOM OF THAILAND Department of Alternative Energy Development and Efficiency MINISTRY OF ENERGY	
KLONG LAM PLOK HYDROPOWER PROJECT	
CIVIL WORKS AND TRANSMISSION LINE WEIR : INTAKE STRUCTURE MISCELLANEOUS DETAILS	
DESIGNED <i>[Signature]</i> NB.29074 DRAWN <i>[Signature]</i>	REVIEWED <i>[Signature]</i> SUBMITTED <i>[Signature]</i> RECOMMENDED <i>[Signature]</i>
CHECKED <i>[Signature]</i> NB.6226 PROJECT MANAGER	APPROVED <i>[Signature]</i> DATE 08/03/2559
DRAWING NO. KLP-WE-08	SHEET NO. 17 OF 110

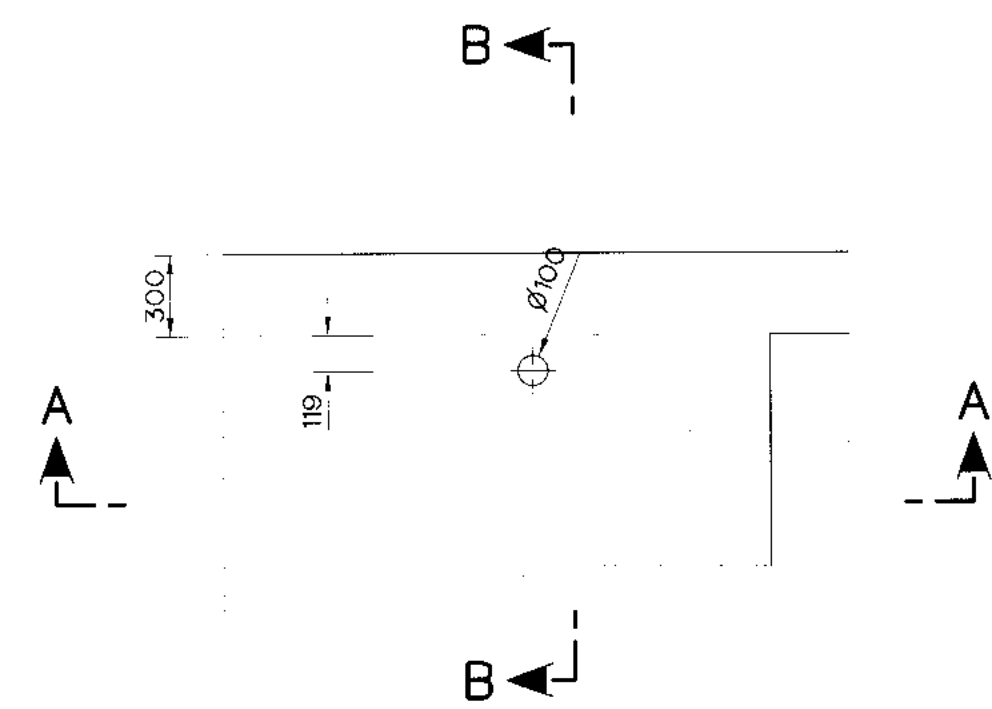


PLAN
NOT TO SCALE

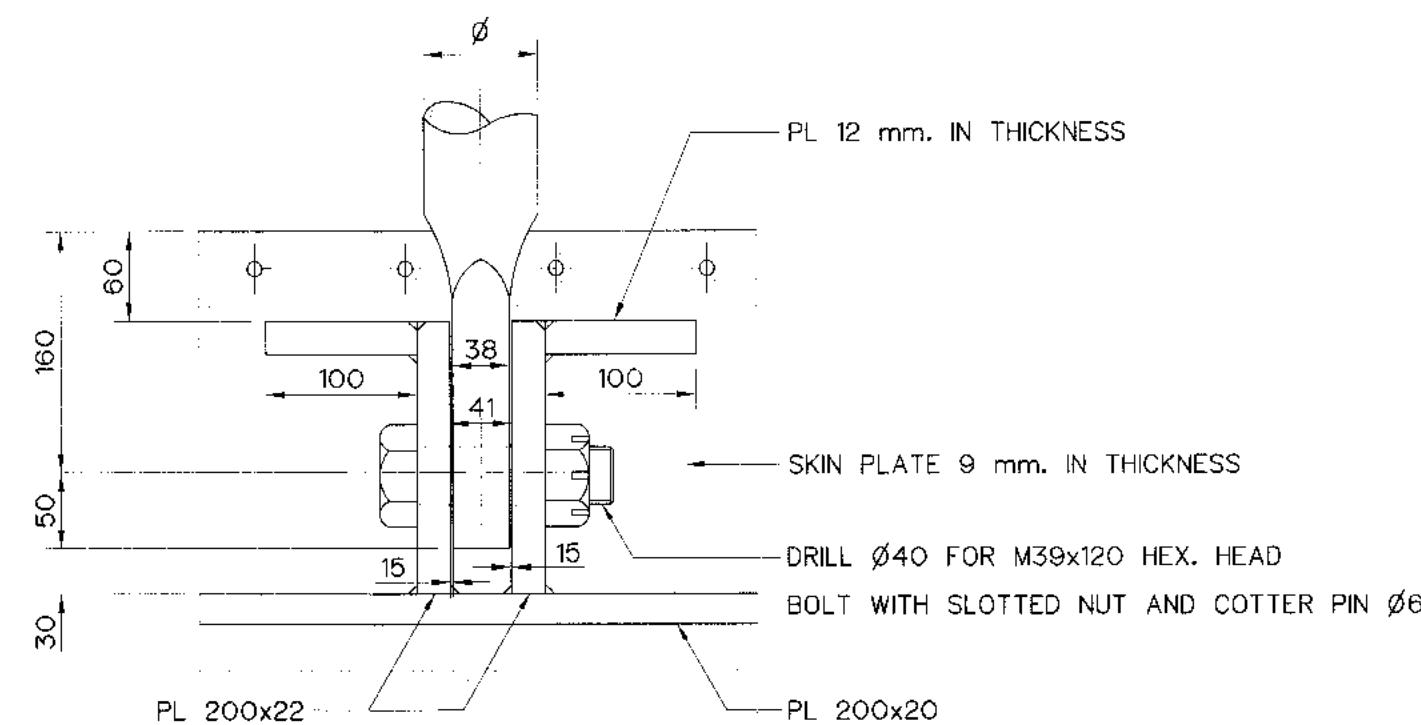


DETAIL "1"
NOT TO SCALE

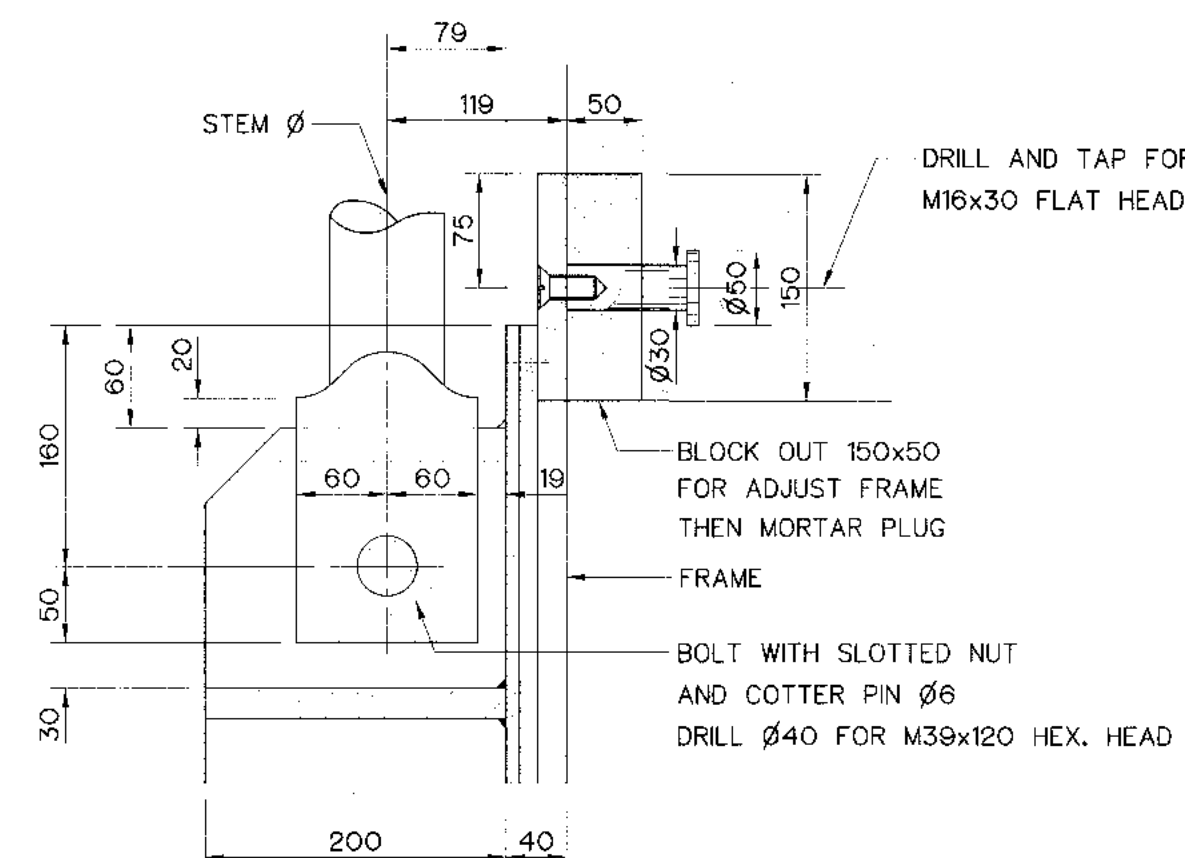


DETAIL "2"
NOT TO SCALE

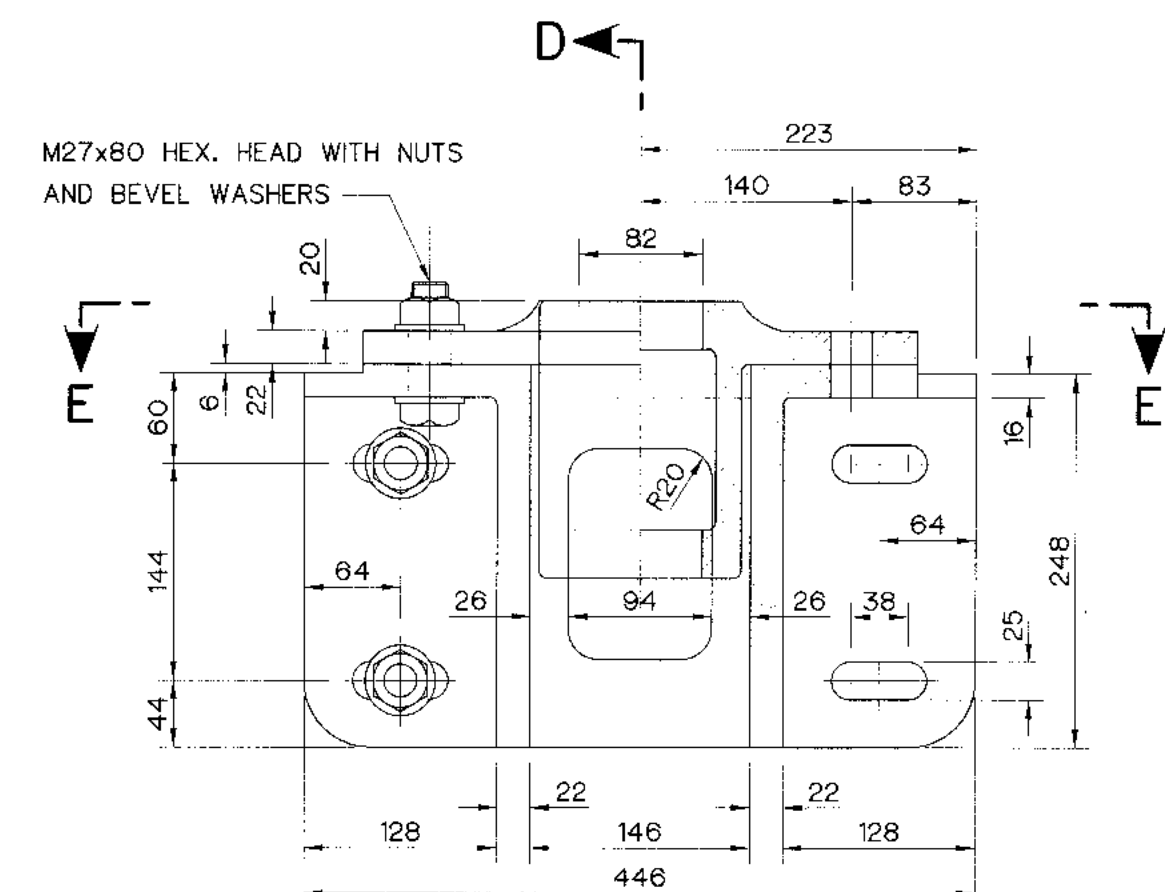


STEM GUIDE
NOT TO SCALE

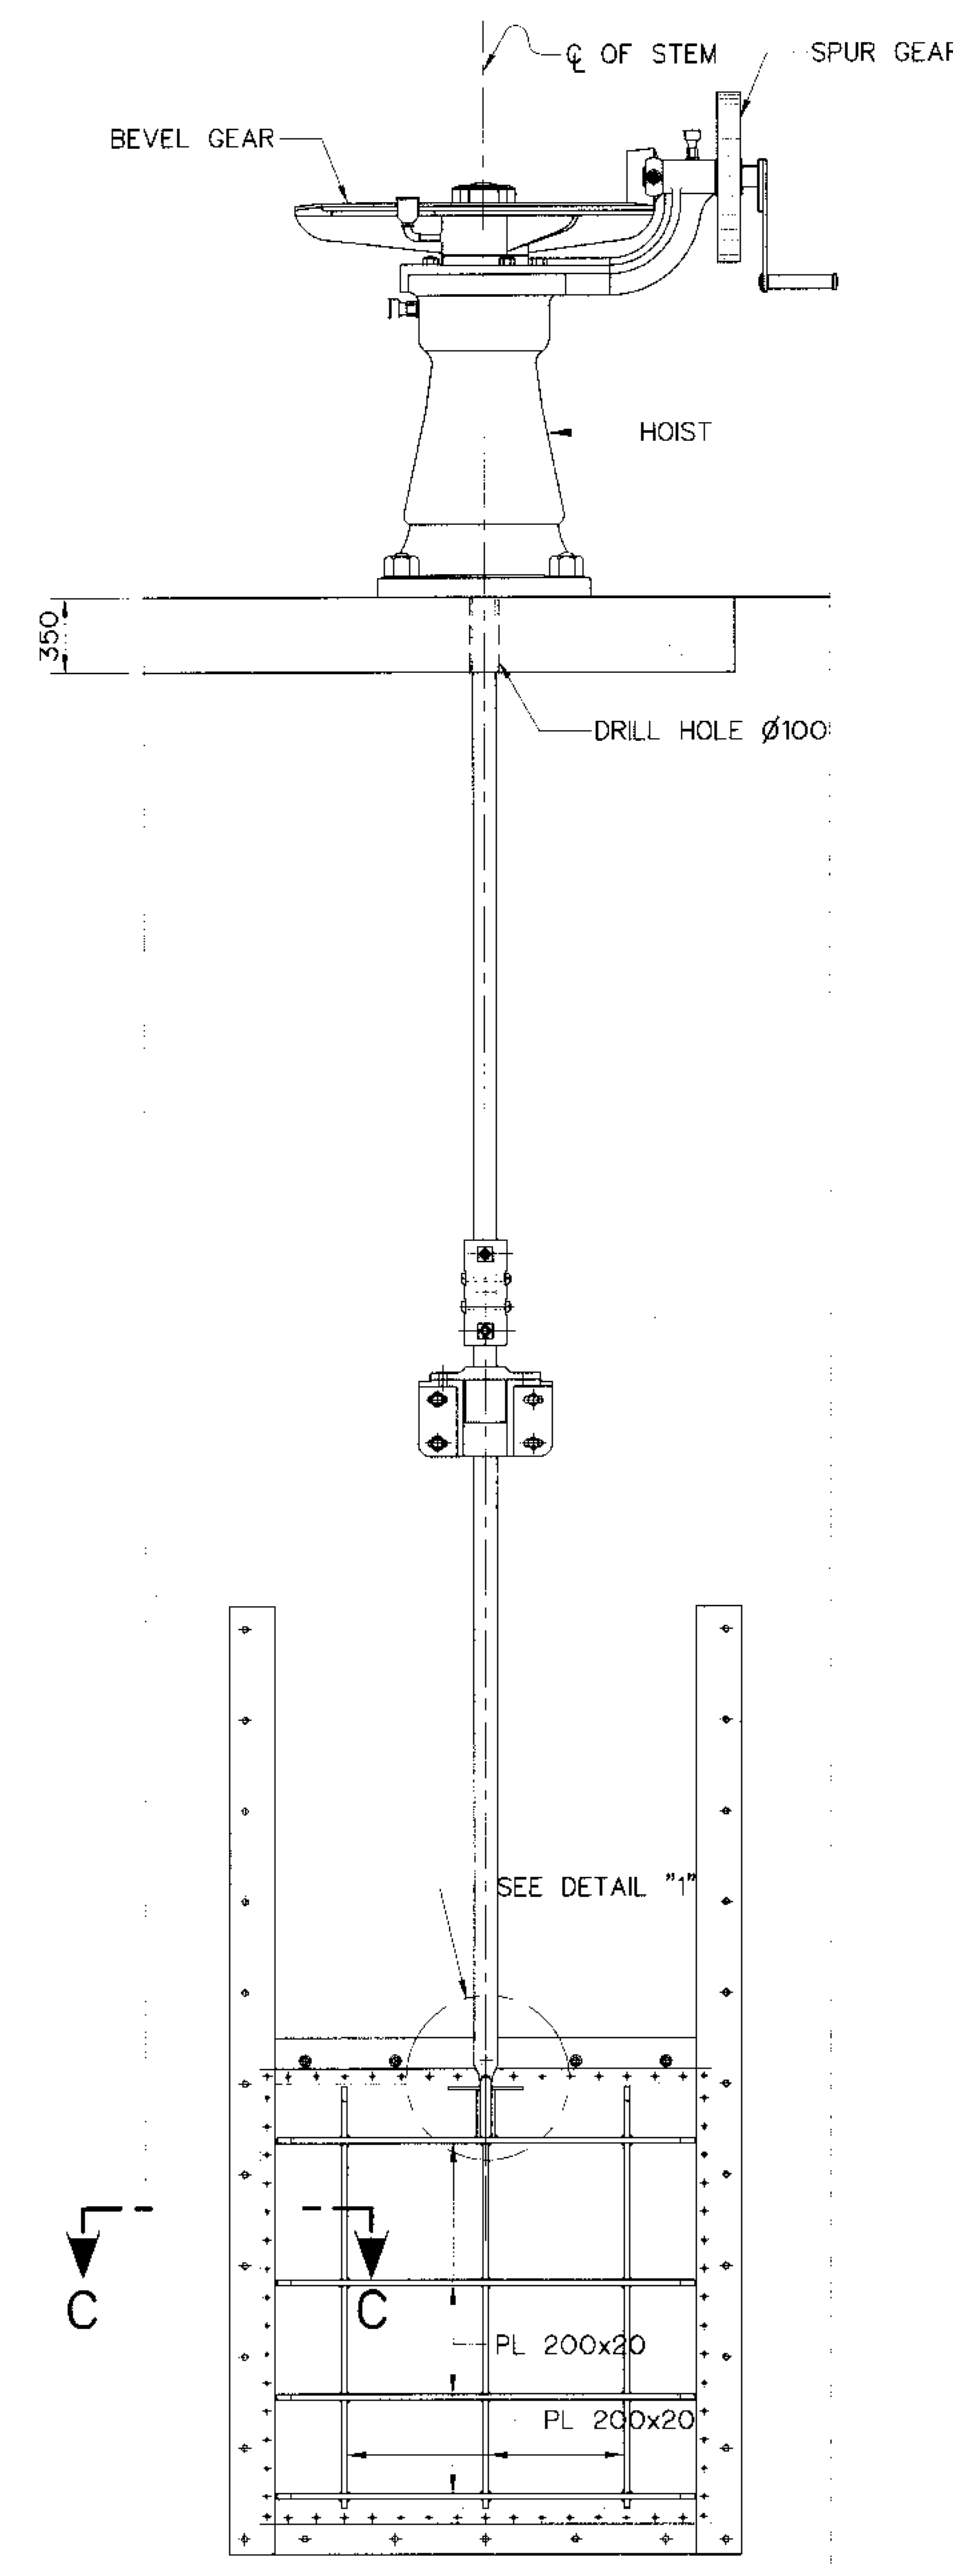


SECTION A-A
NOT TO SCALE

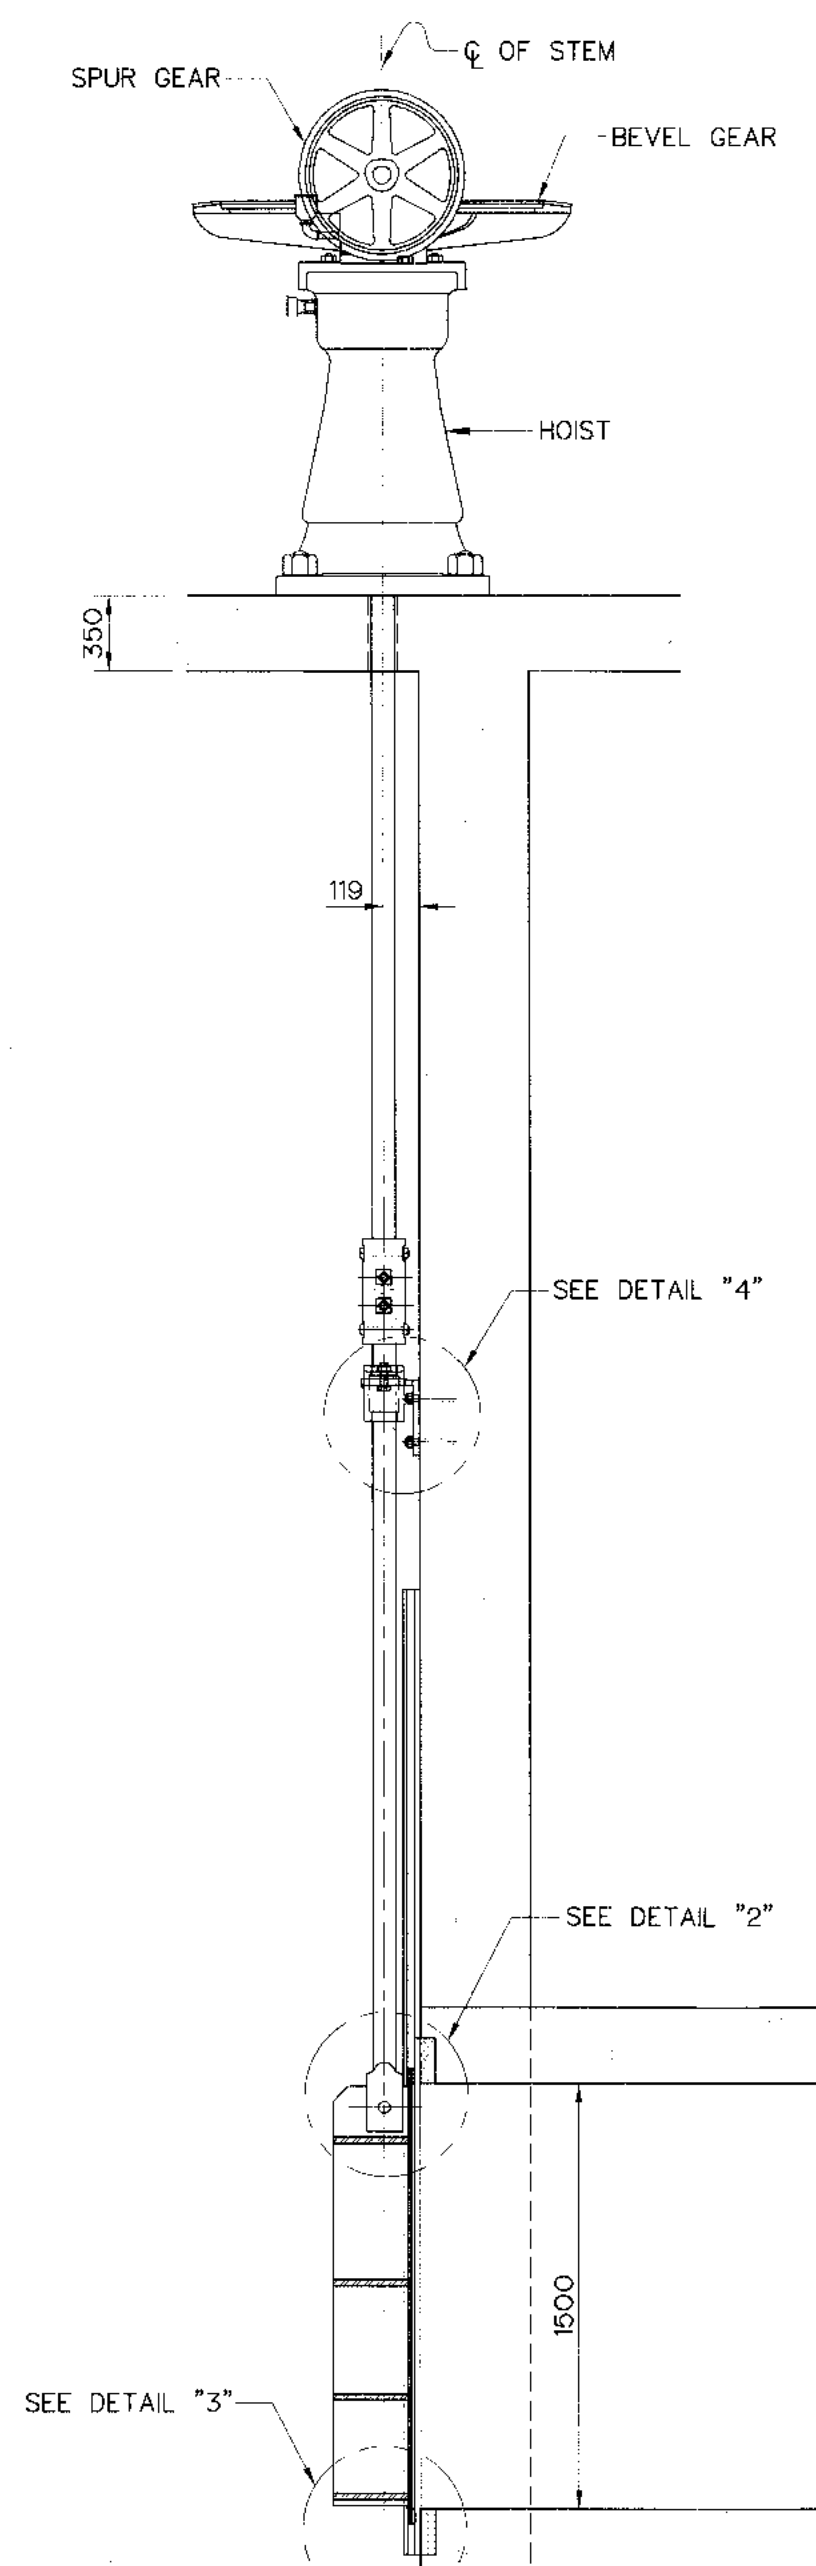


SECTION B-B
NOT TO SCALE

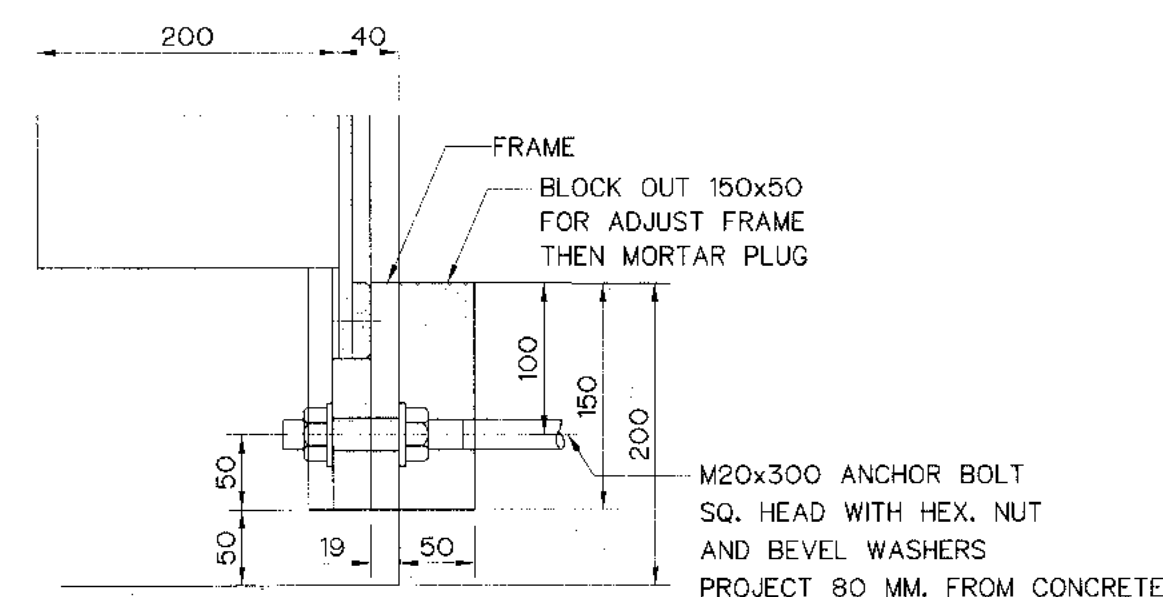


DETAIL "3"
SCALE 1:5

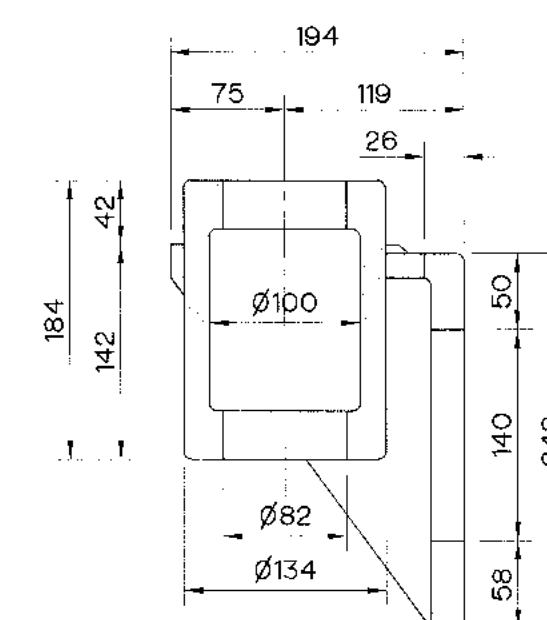


SECTION D-D
SCALE 1:5

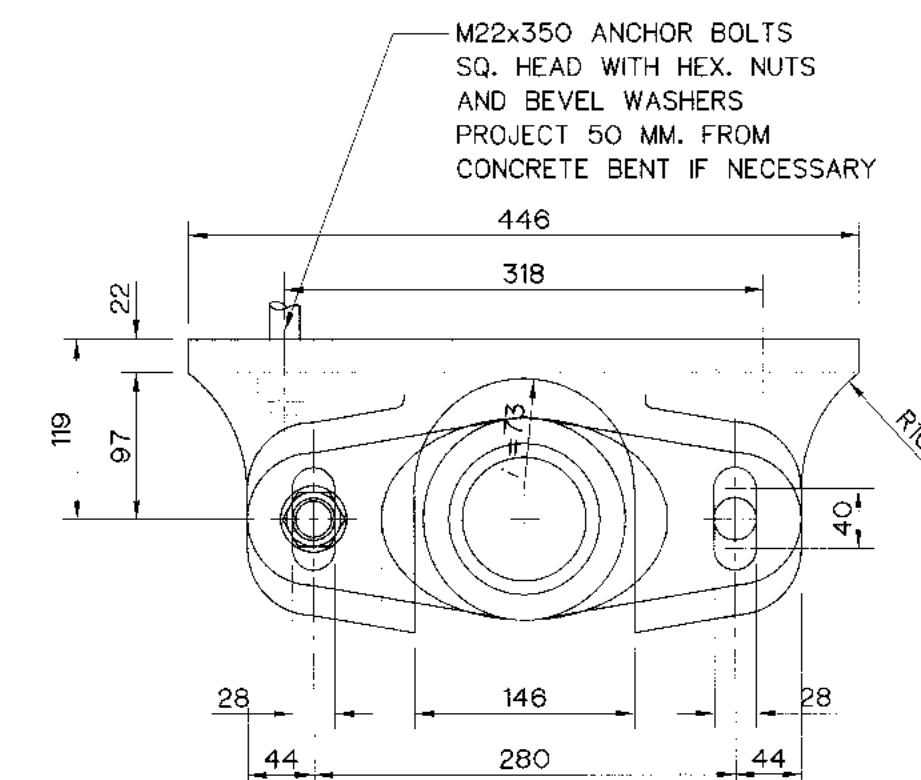

SECTION E-E
SCALE 1:5

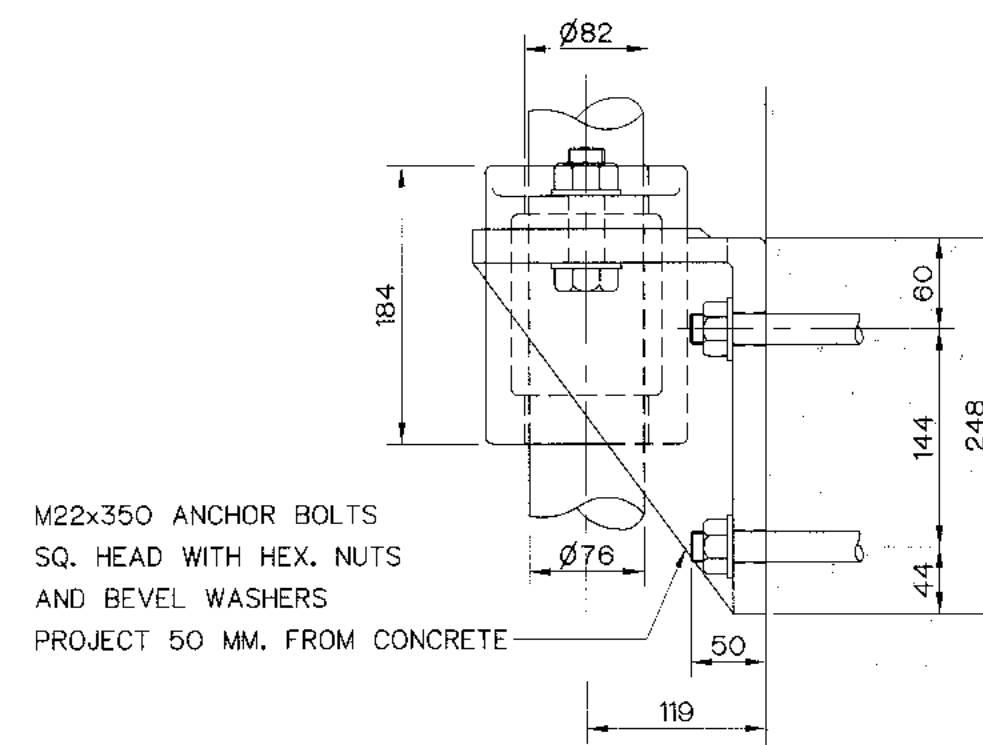

DETAIL "4"
SCALE 1:5

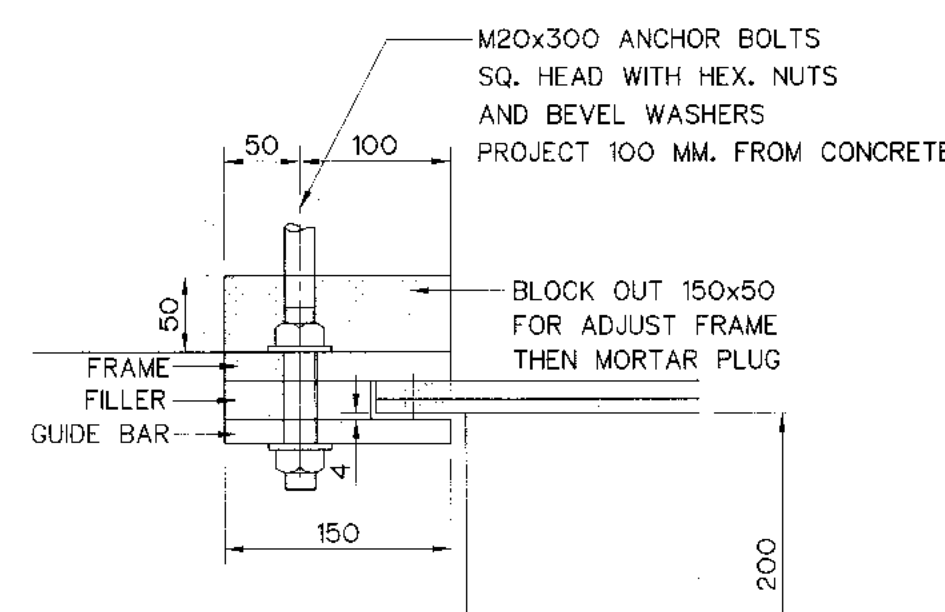

SECTION C-C
SCALE 1:5

NOTE :


1. ALL DIMENSIONS ARE IN MILLIMETERS, AND ELEVATION ARE IN METERS UNLESS OTHERWISE SHOWN.
2. ALL WELDING WILL BE 6 MILLIMETERS, UNLESS OTHERWISE SHOWN.
3. ALL BOLTS AND NUTS USE ASTM A325.
4. ALL STRUCTURAL STEELS ARE JIS G 3101 SS400
5. ALL STAINLESS STEELS PLATES ARE JIS G 4304 SUS 304.
6. THIS DRAWING IS DESIGNED FOR GUIDE LINE ONLY, THE CONTRACTOR HAS TO SUBMITTED SHOP DRAWING TO FIELD ENGINEER FOR APPROVAL

REFERENCE DWGS :


1. WEIR : INTAKE STRUCTURE PLAN AND SECTIONS KLP-WE-04
2. WEIR : INTAKE STRUCTURE 1.50x1.50 m. VERTICAL GATE (GATE DETAIL) KLP-WE-10
3. WEIR : PEDESTAL SCREW LIFT CAPACITY 6.5 TONS KLP-WE-12

KINGDOM OF THAILAND Department of Alternative Energy Development and Efficiency MINISTRY OF ENERGY	
KLONG LAM PLOK HYDROPOWER PROJECT	
CIVIL WORKS AND TRANSMISSION LINE	
WEIR : INTAKE STRUCTURE	
1.50x1.50 m. VERTICAL GATE (GATE INSTALLATION)	
DESIGNED <i>[Signature]</i> 28.29074 28.6226	REVIEWED <i>[Signature]</i>
DRAWN <i>[Signature]</i>	SUBMITTED <i>[Signature]</i>
CHECKED <i>[Signature]</i> 28.6226	RECOMMENDED <i>[Signature]</i>
APPROVED <i>[Signature]</i>	APPROVED <i>[Signature]</i>
PROJECT MANAGER <i>[Signature]</i> 08/03/2559	DRAWING NO. KLP-WE-09
DATE	SHEET NO. 18 OF 110


NO.	DATE	REVISIONS	CHECKED	APPROVED
3				
2				
1				
CONSULTANTS		DEDE		

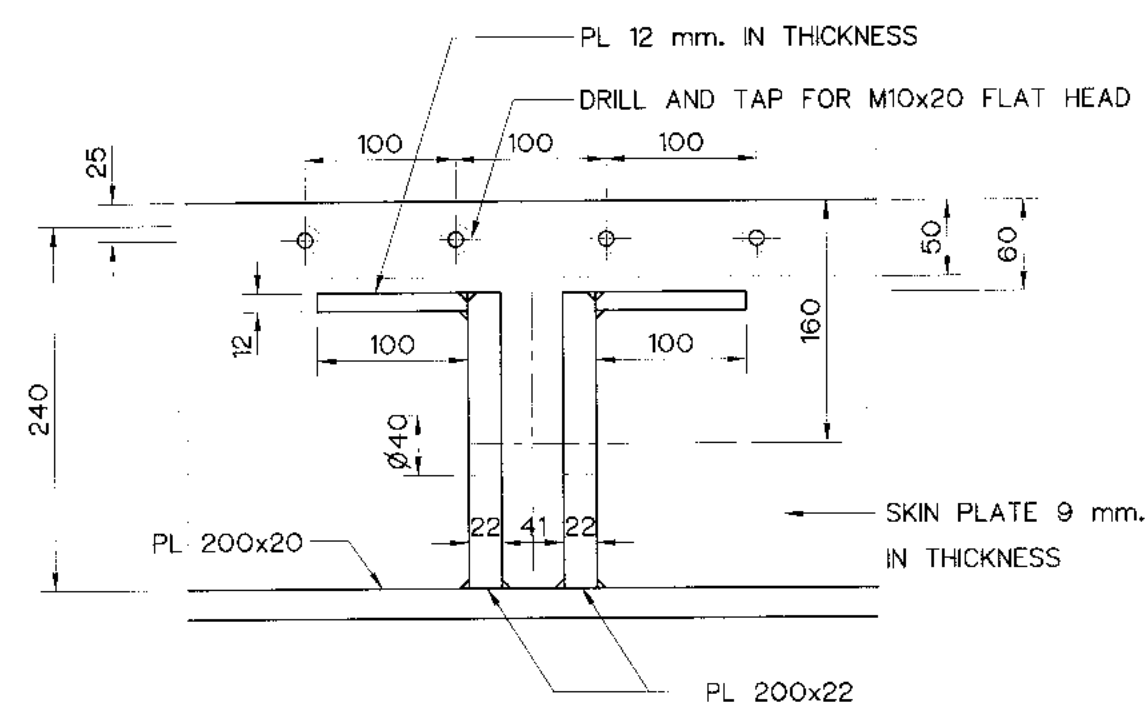


DETAIL "1"
NOT TO SCALE

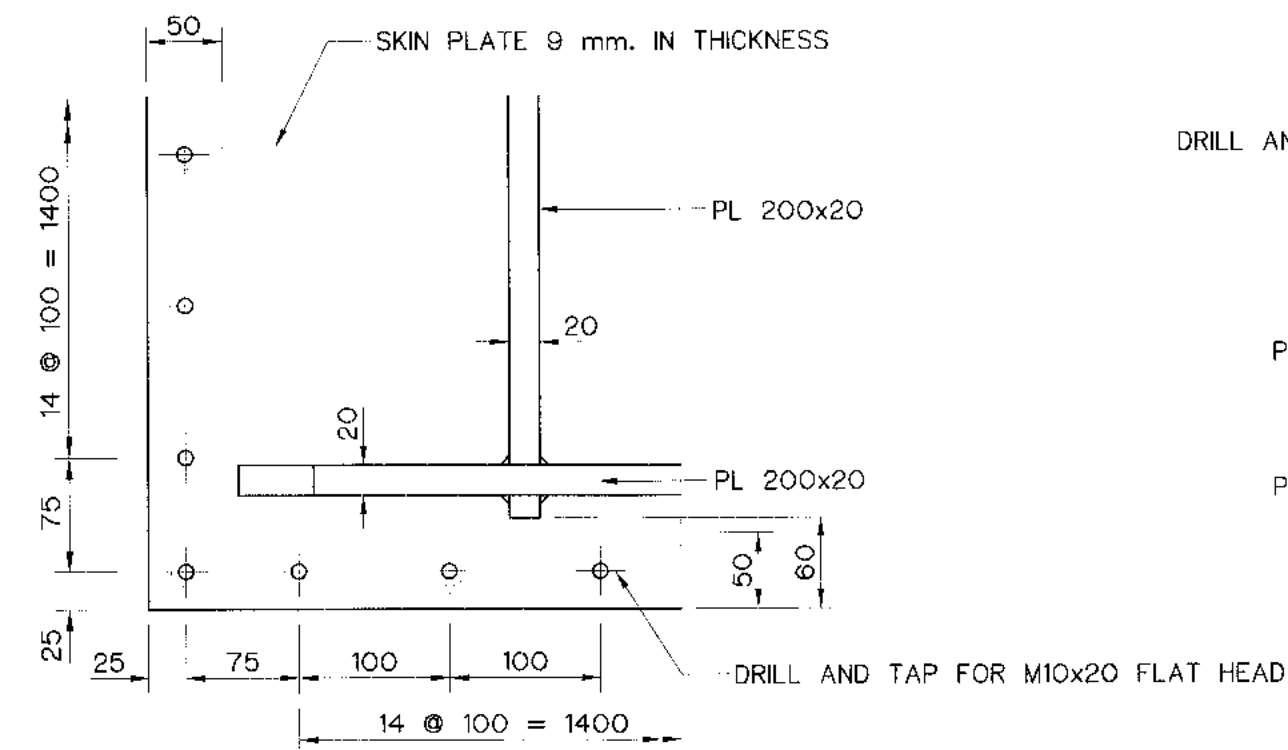


DETAIL "2"
NOT TO SCALE

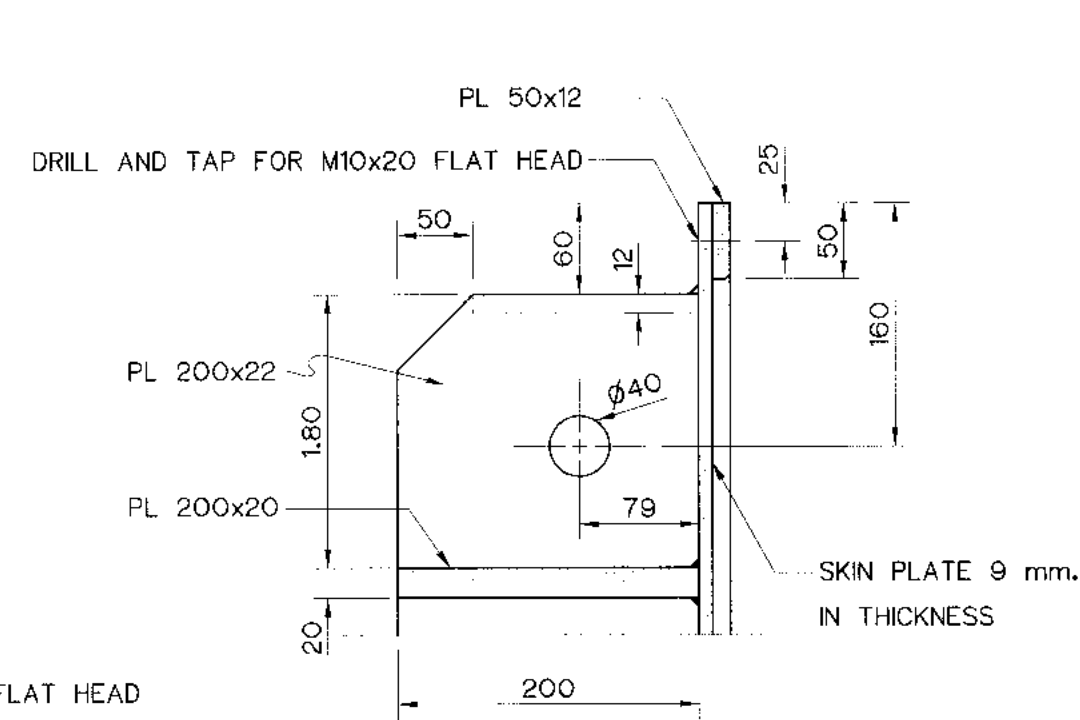


DETAIL "3"
NOT TO SCALE

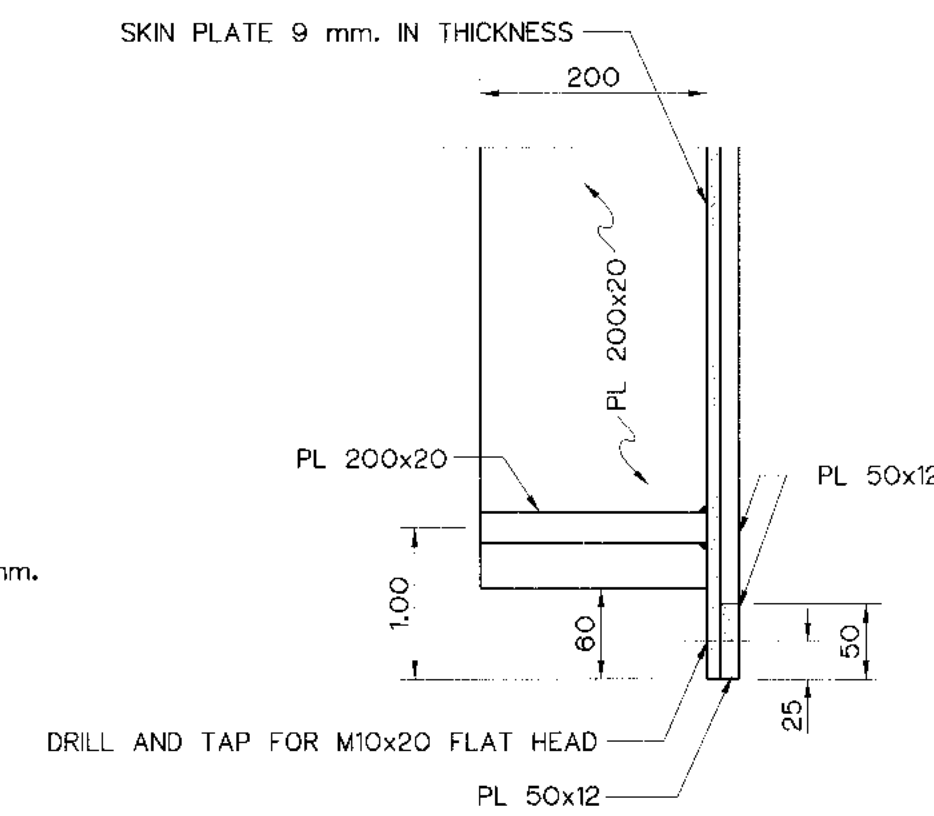



DETAIL "4"
NOT TO SCALE

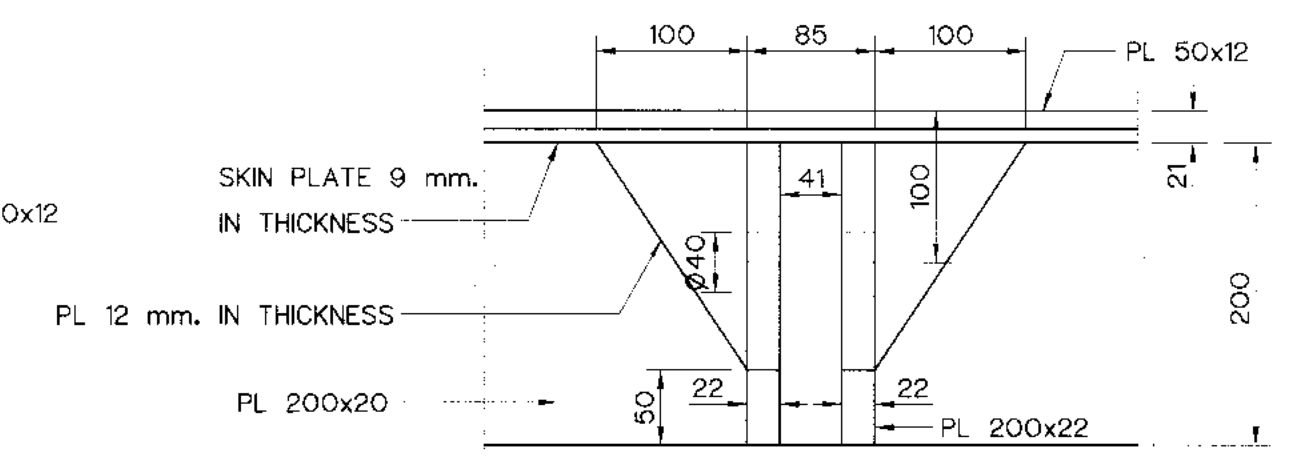


DETAIL "5"
NOT TO SCALE

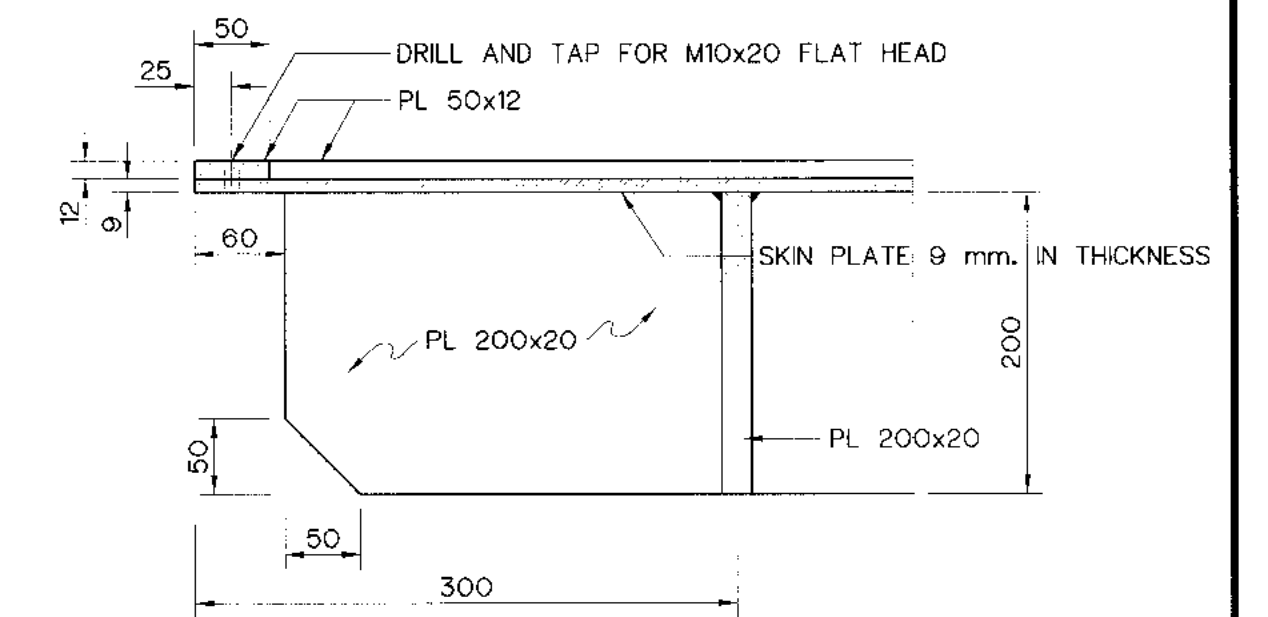

SECTION B-B
NOT TO SCALE

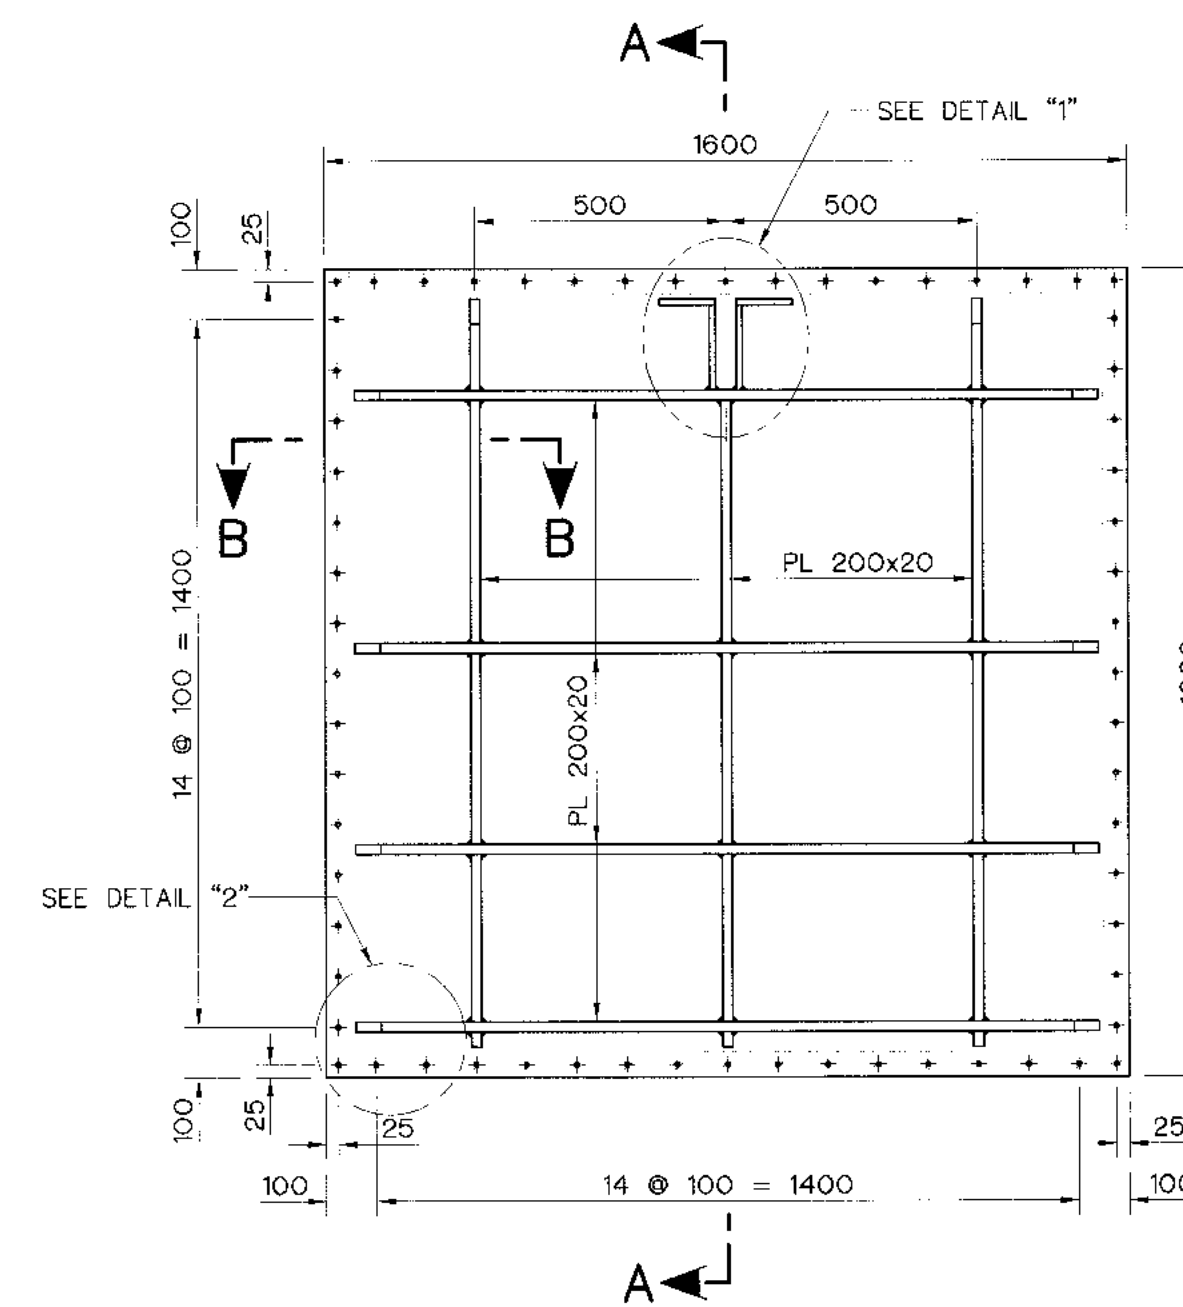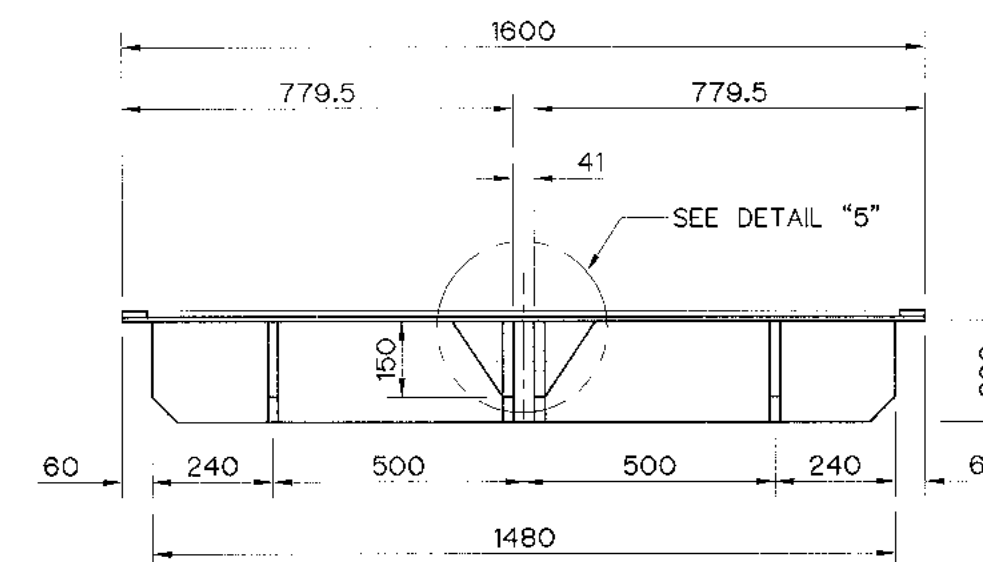

GATE LEAF
NOT TO SCALE

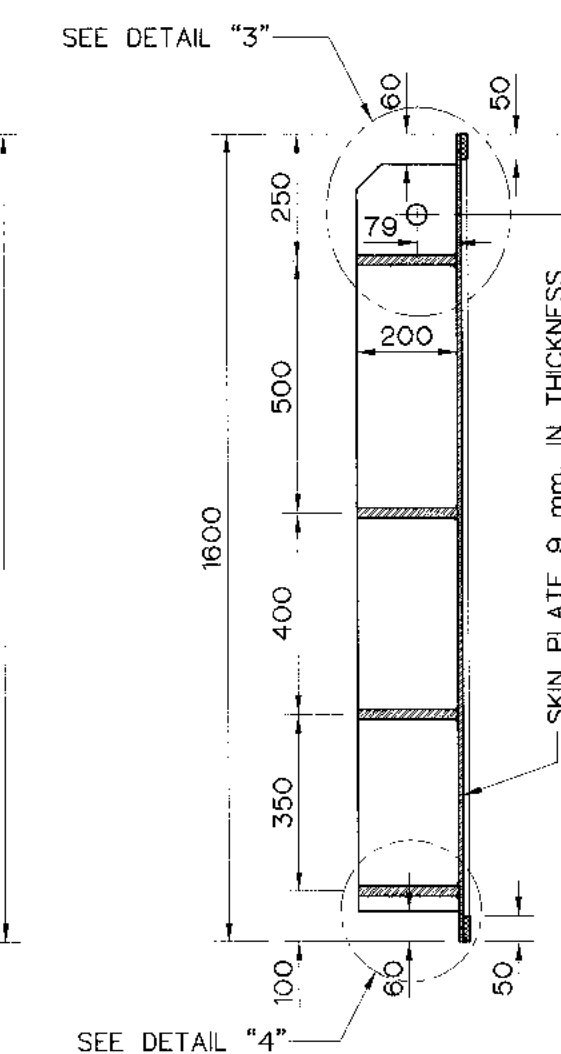


SECTION A-A
NOT TO SCALE

NOTE :


1. ALL DIMENSIONS ARE IN MILLIMETERS, UNLESS OTHERWISE SHOWN.
2. ALL WELDING WILL BE 6 MILLIMETERS, UNLESS OTHERWISE SHOWN.
3. ALL BOLTS AND NUTS USE ASTM A325.
4. ALL STRUCTURAL STEELS ARE JIS G 3101 SS400
5. ALL STAINLESS STEELS PLATES ARE JIS G 4304 SUS 304.
6. THIS DRAWING IS DESIGNED FOR GUIDE LINE ONLY, THE CONTRACTOR HAS TO SUBMITTED SHOP DRAWING TO FIELD ENGINEER FOR APPROVAL

REFERENCE DWGS :


- | | |
|---|-----------|
| 1. WEIR : INTAKE STRUCTURE 1.50x1.50 m. VERTICAL GATE (GATE INSTALLATION) | KLP-WE-09 |
| 2. WEIR : PEDESTAL SCREW LIFT CAPACITY 6.5 TONS | KLP-WE-12 |

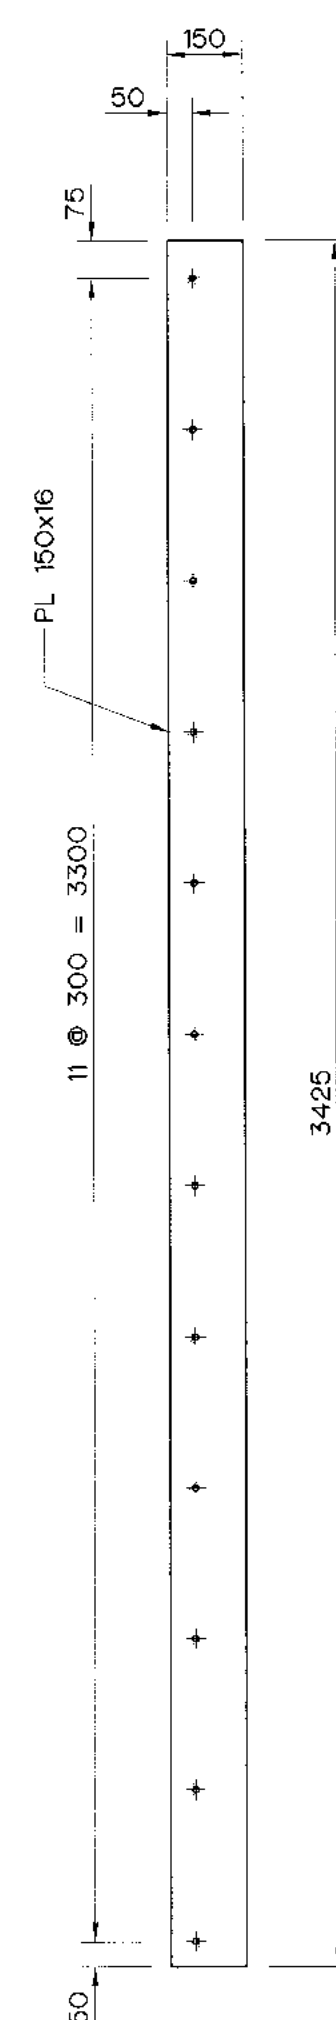


GUIDE BAR
NOT TO SCALE

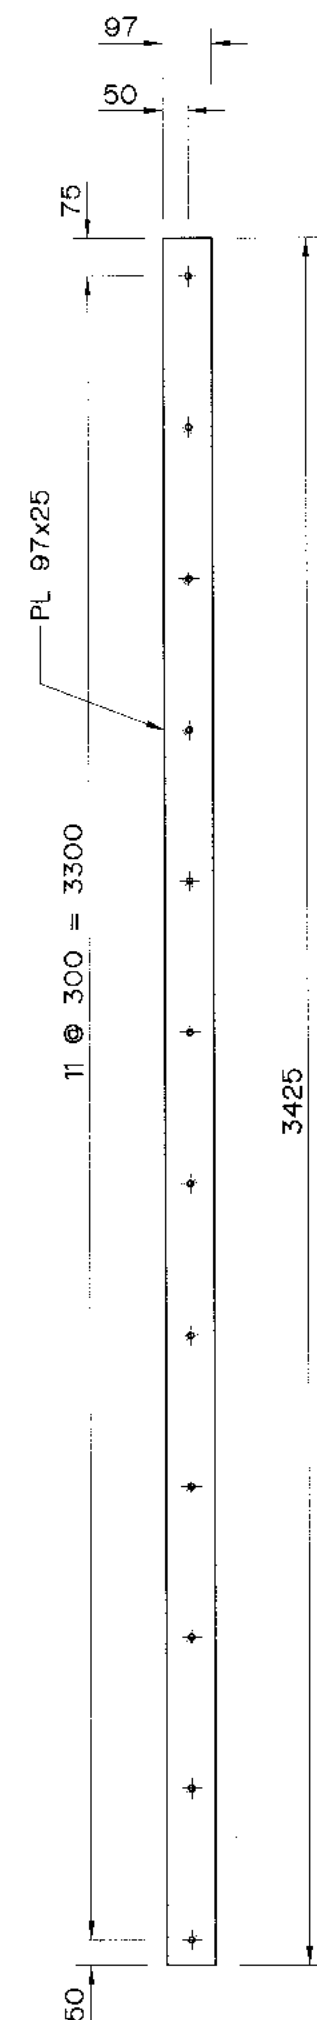

FILLER
NOT TO SCALE












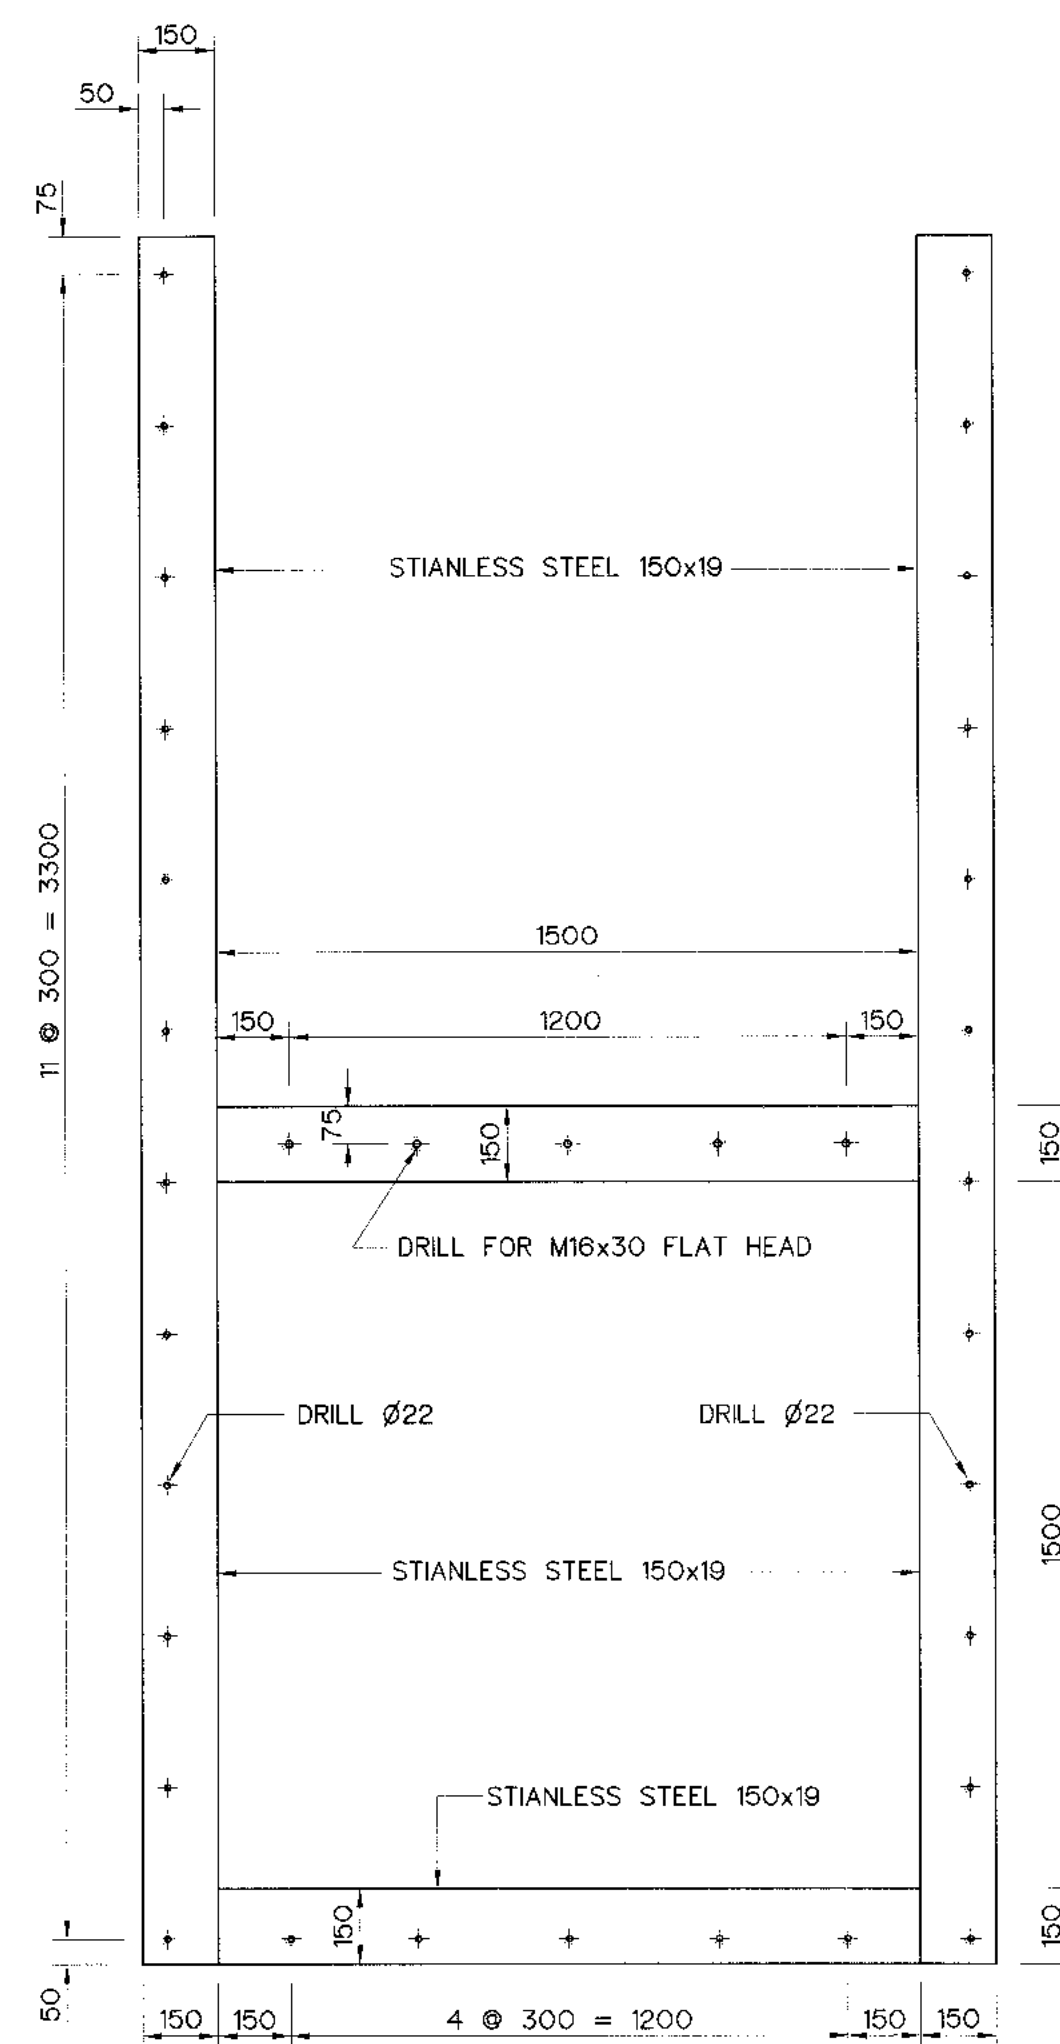


FRAME
NOT TO SCALE

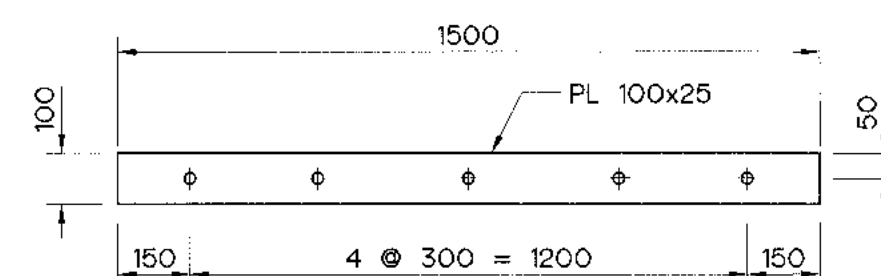










BOTTOM BAR
NOT TO SCALE

3						 P&C MANAGEMENT CO.,LTD.	 MINISTRY OF ENERGY	
2							DESIGNED <i>[Signature]</i> 19.29074 08.03.2559	REVIEWED <i>[Signature]</i>
1							DRAWN <i>[Signature]</i>	SUBMITTED <i>[Signature]</i>
NO.	DATE	REVISIONS	CHECKED	APPROVED	CHECKED <i>[Signature]</i> 08.03.2559	APPROVED <i>[Signature]</i>	RECOMMENDED <i>[Signature]</i>	
	CONSULTANTS		DEDE		 08/03/2559 PROJECT MANAGER	DRAWING NO. KLP-WE-10		SHEET NO. 19 of 110

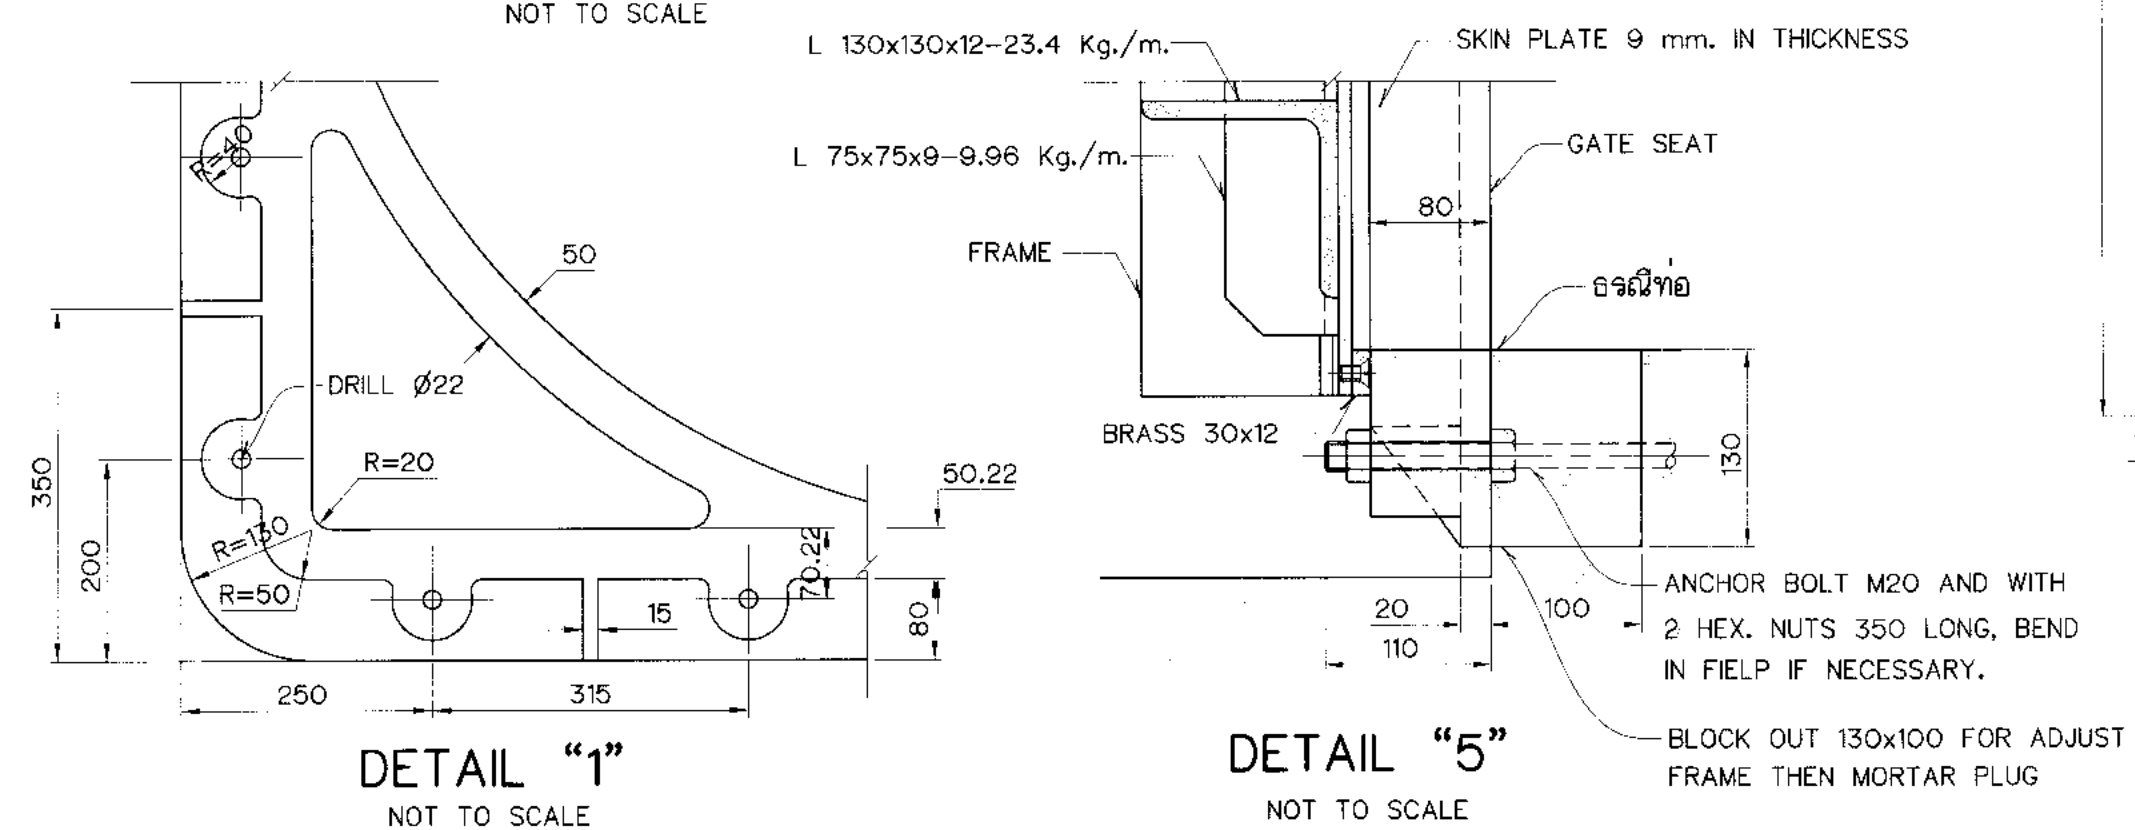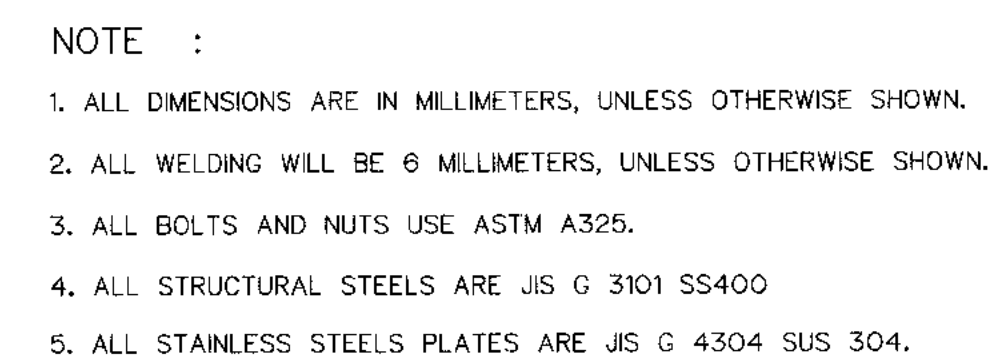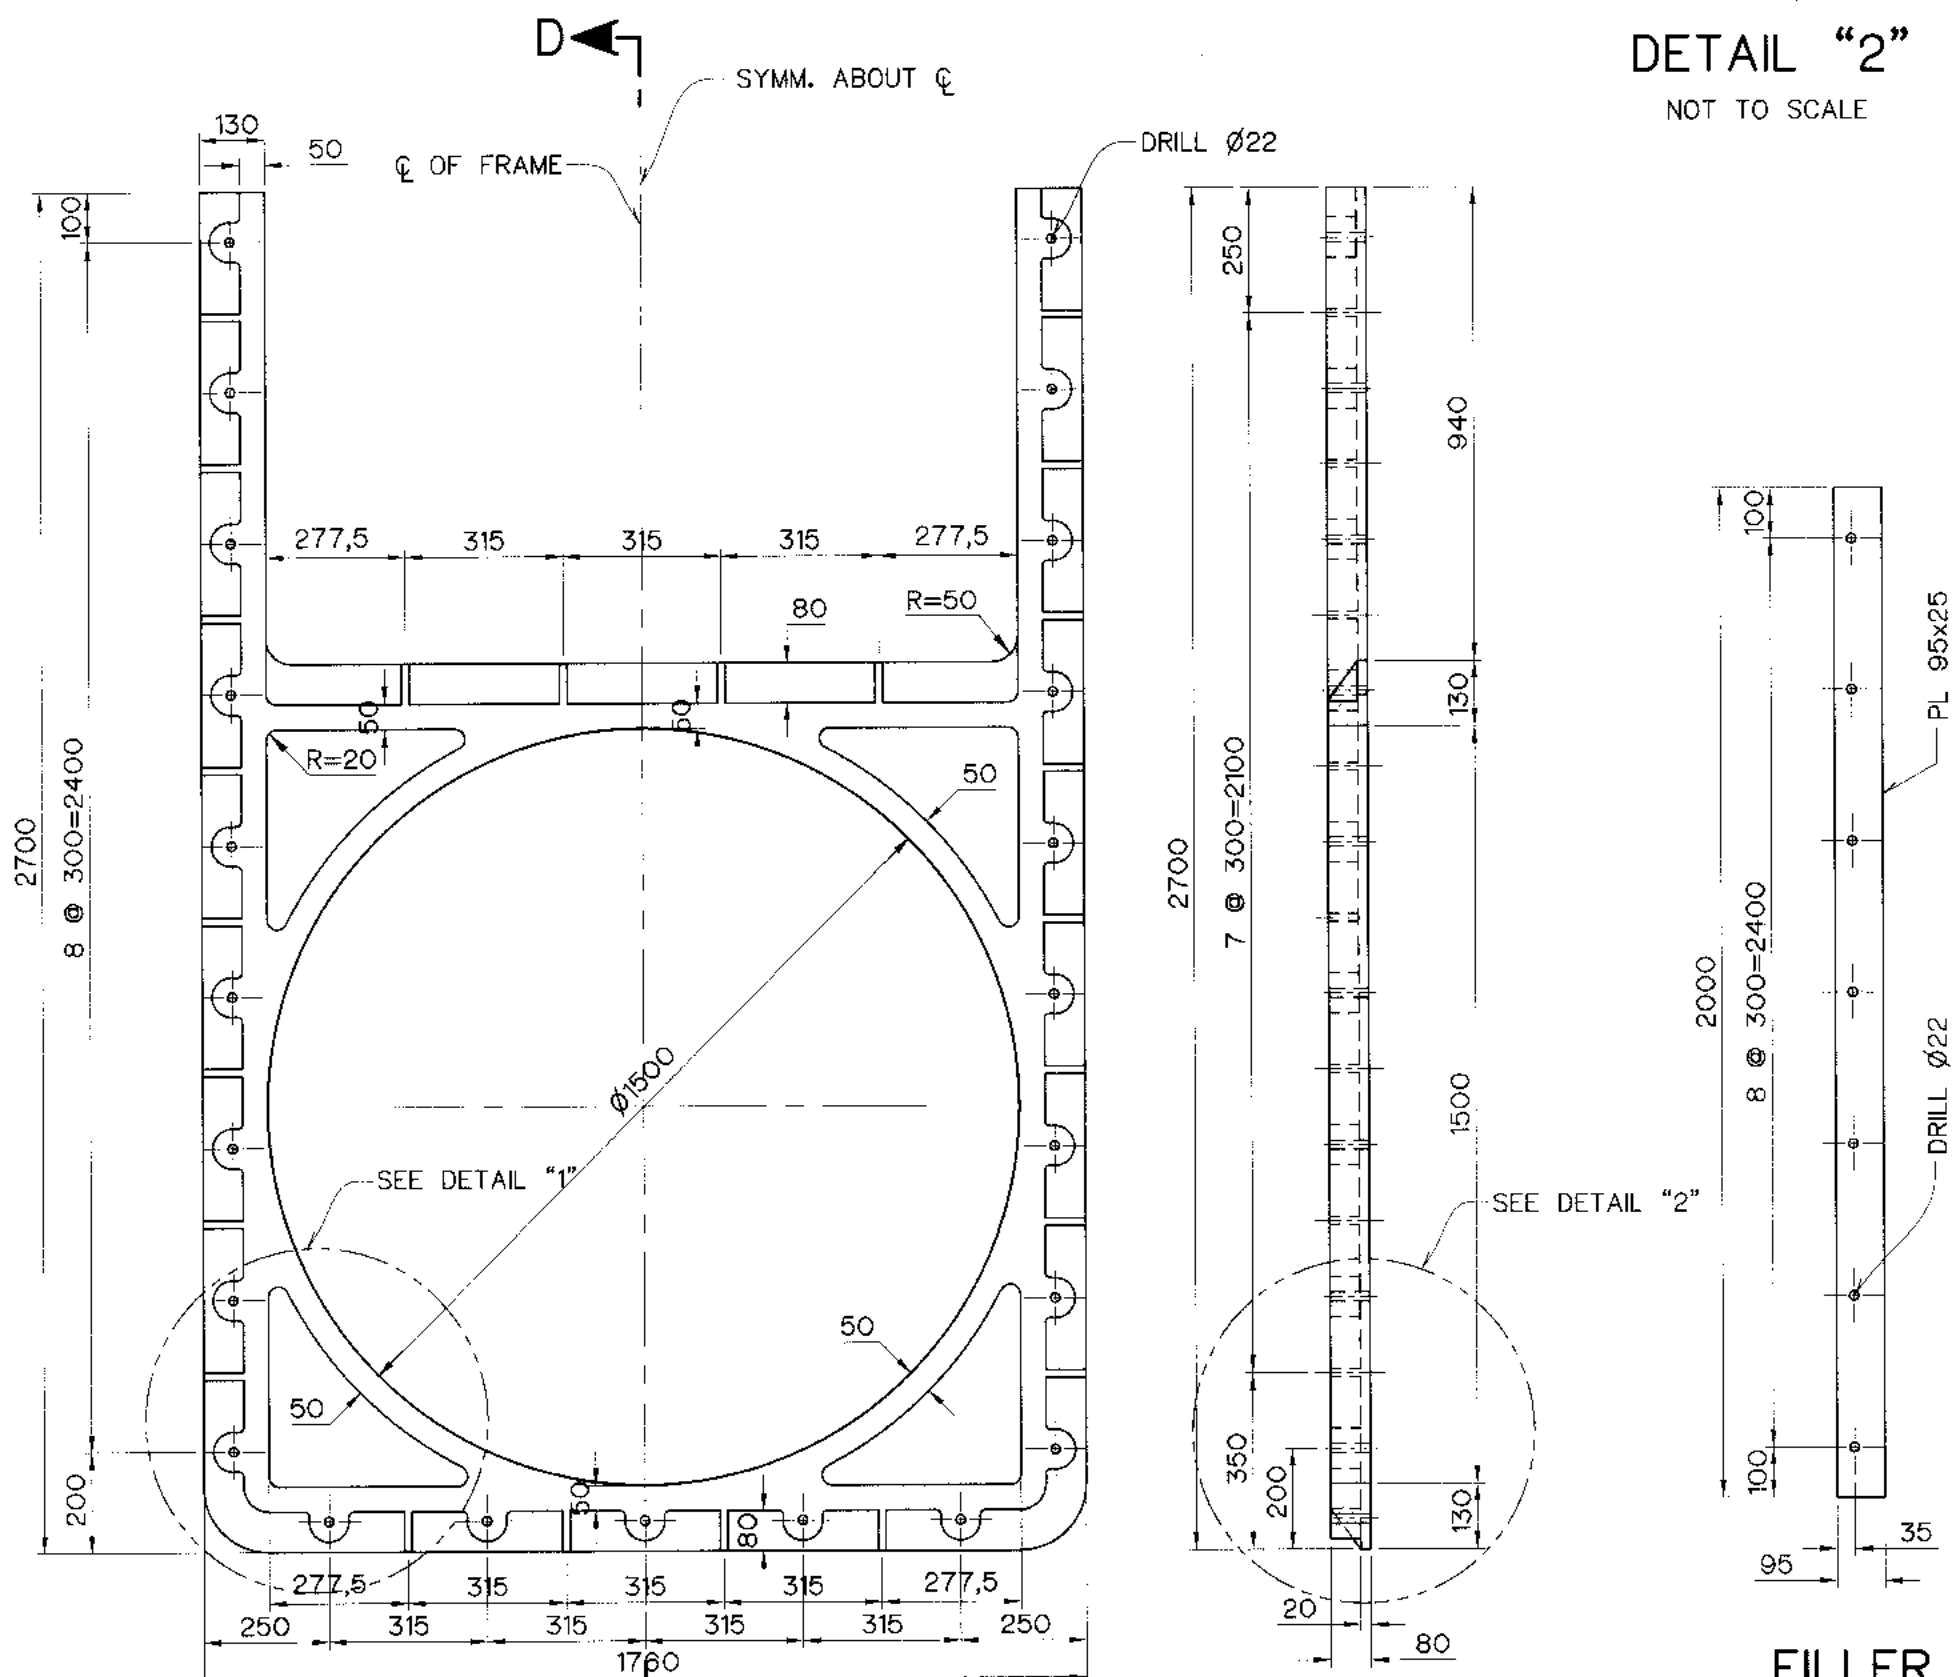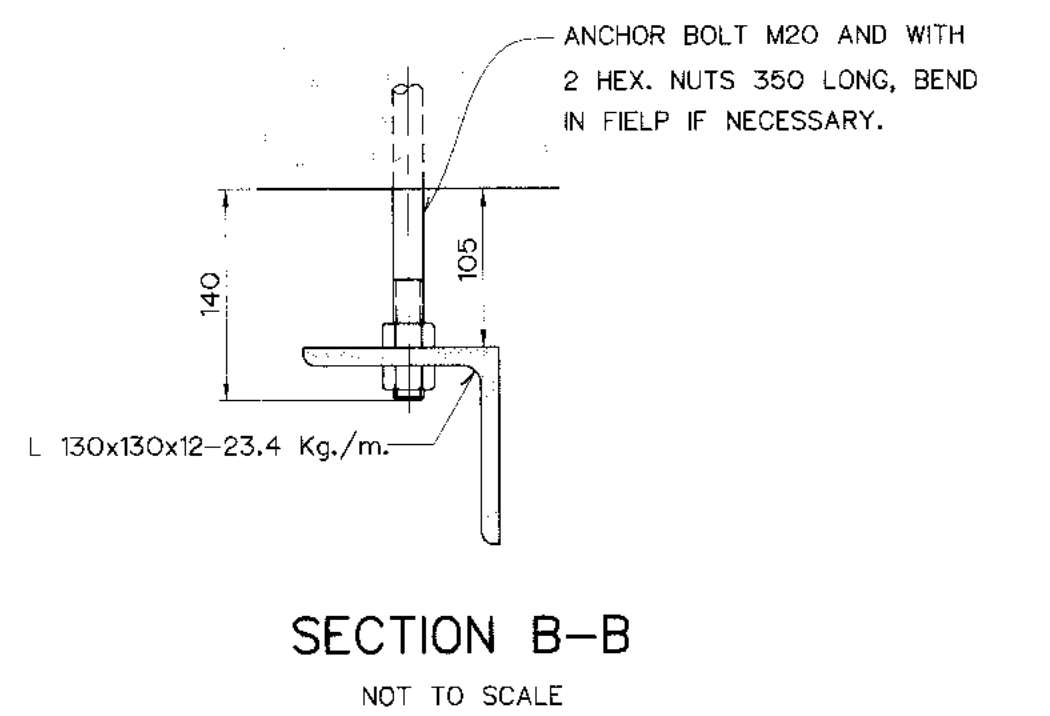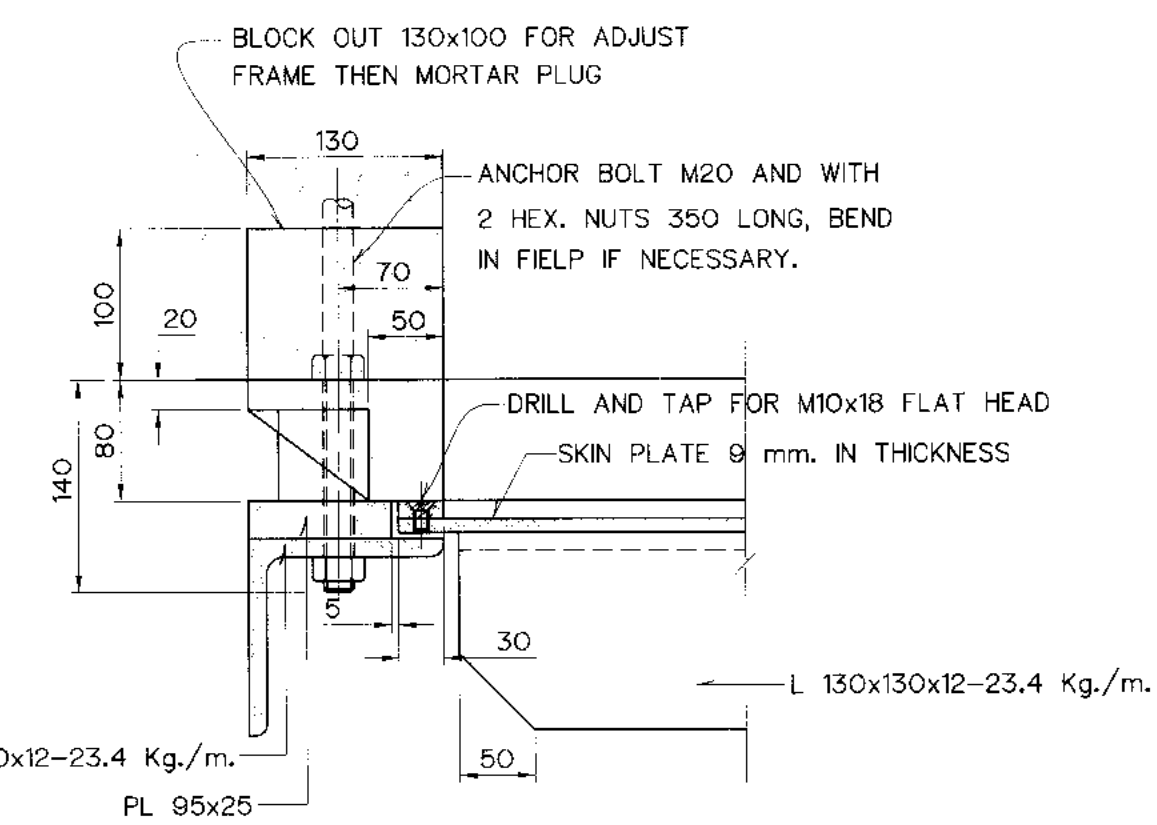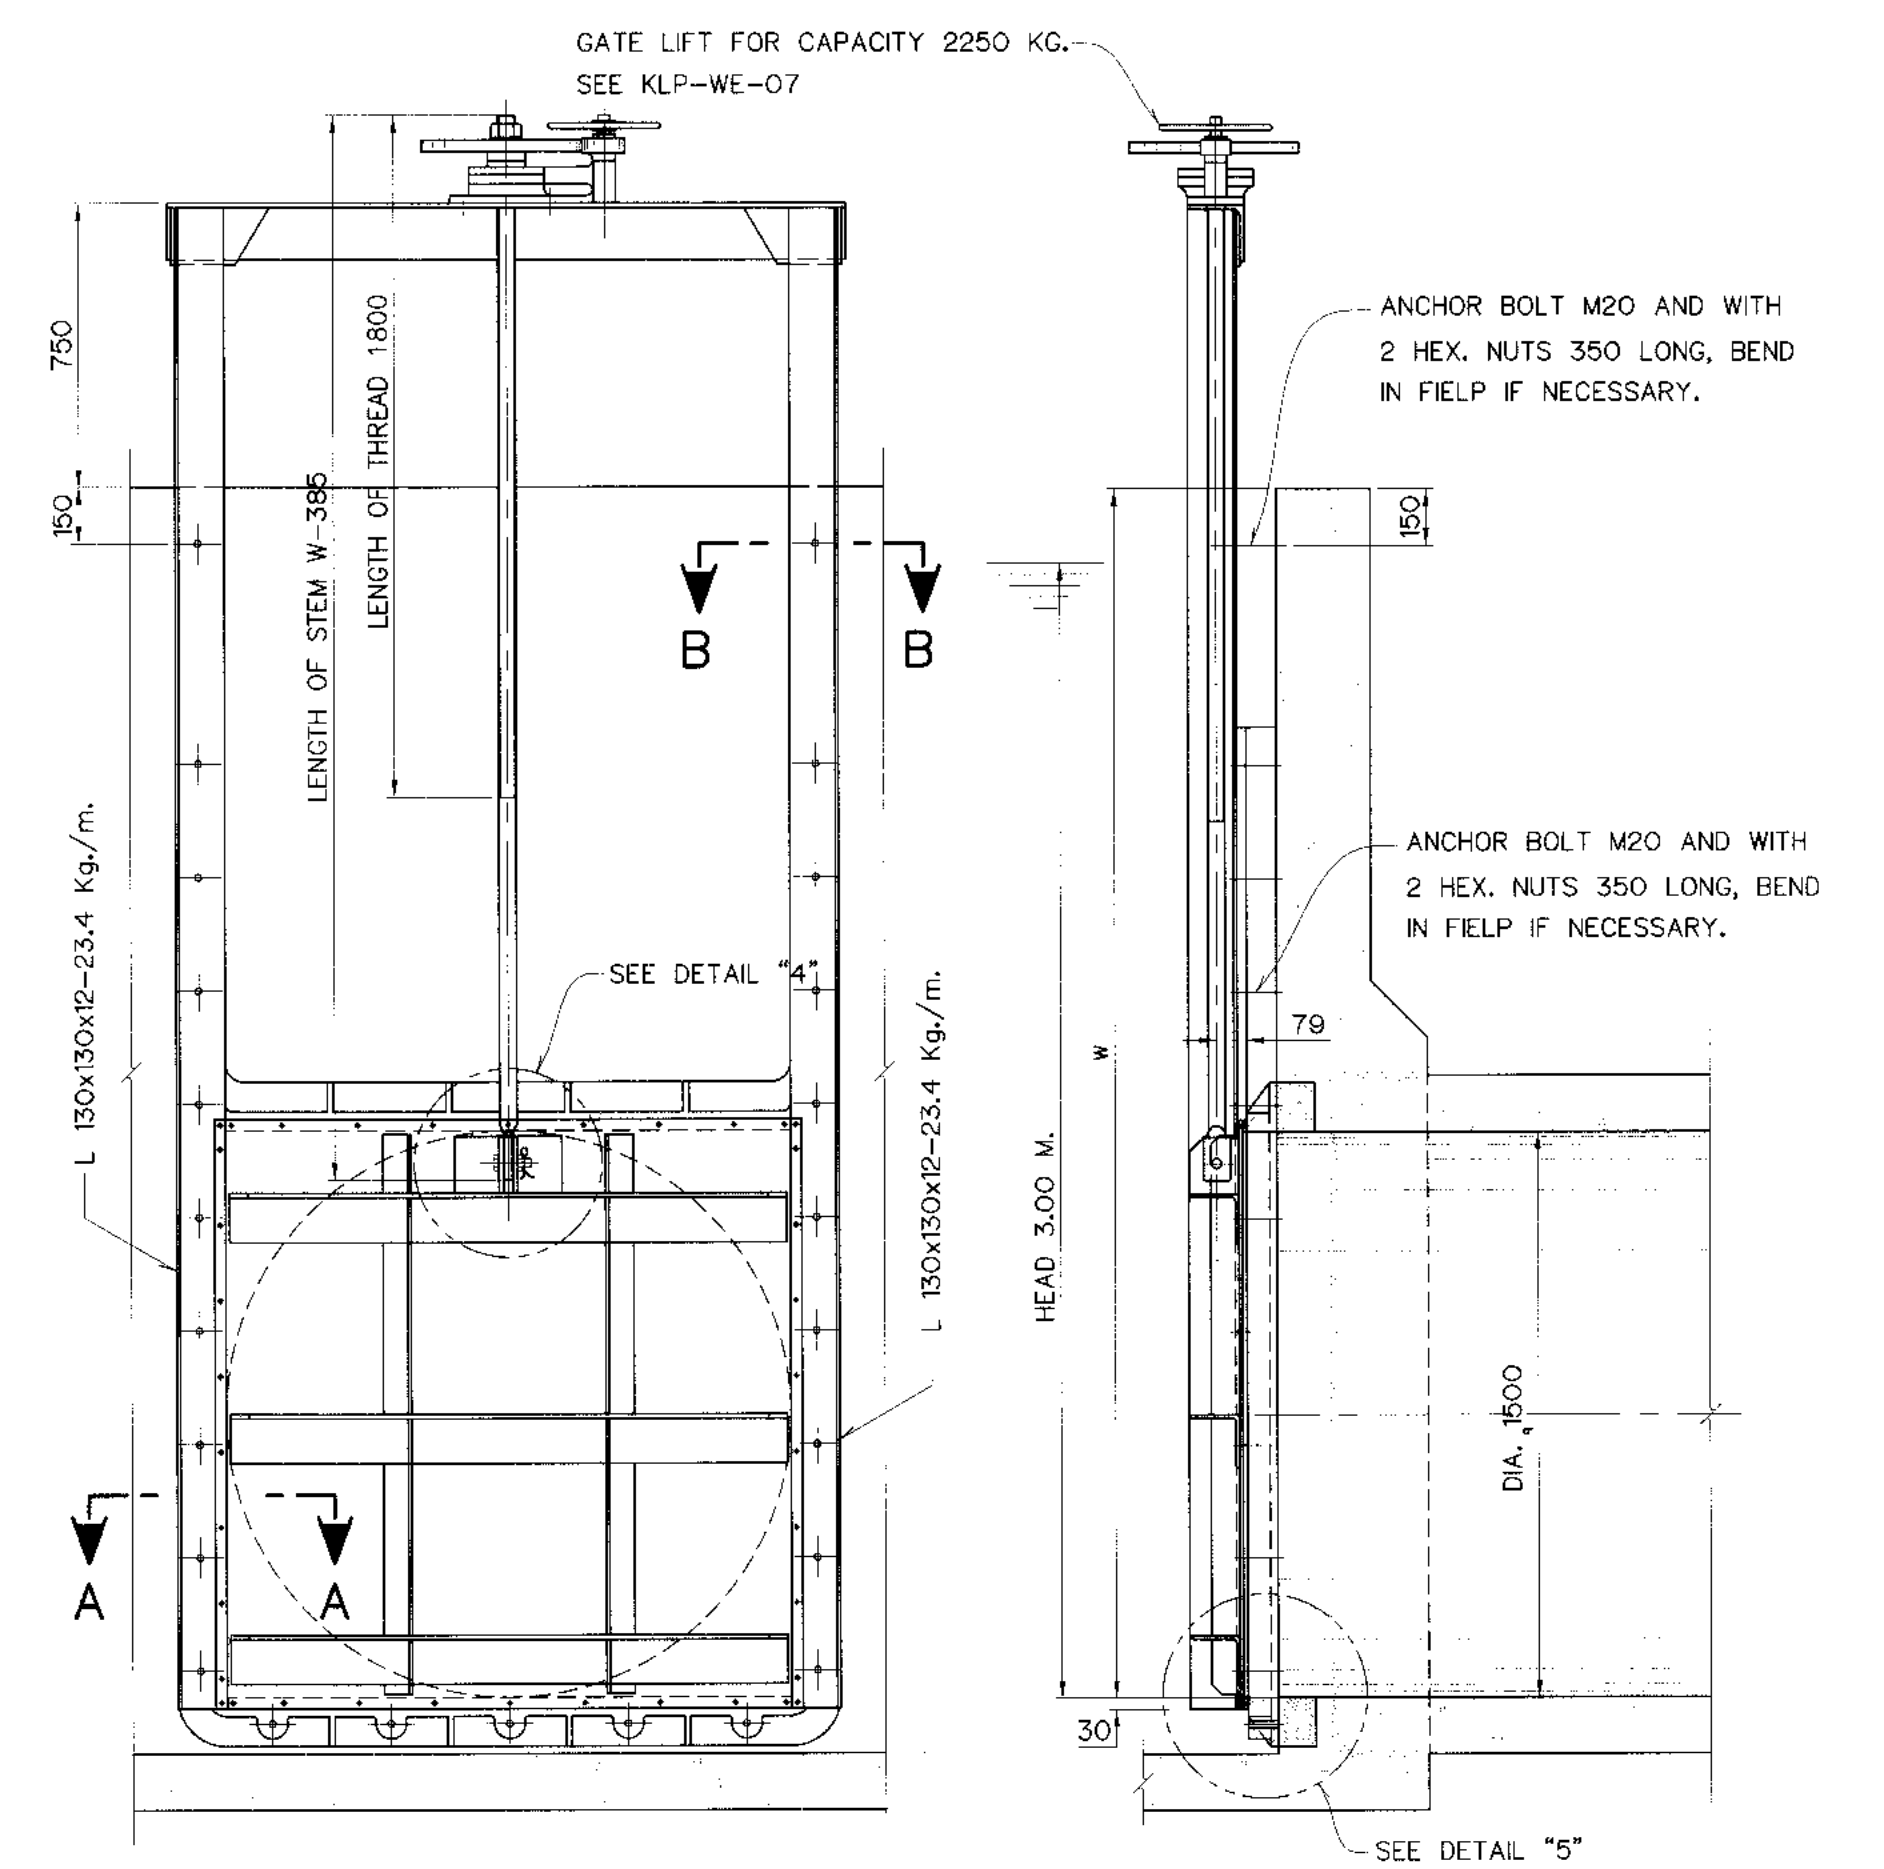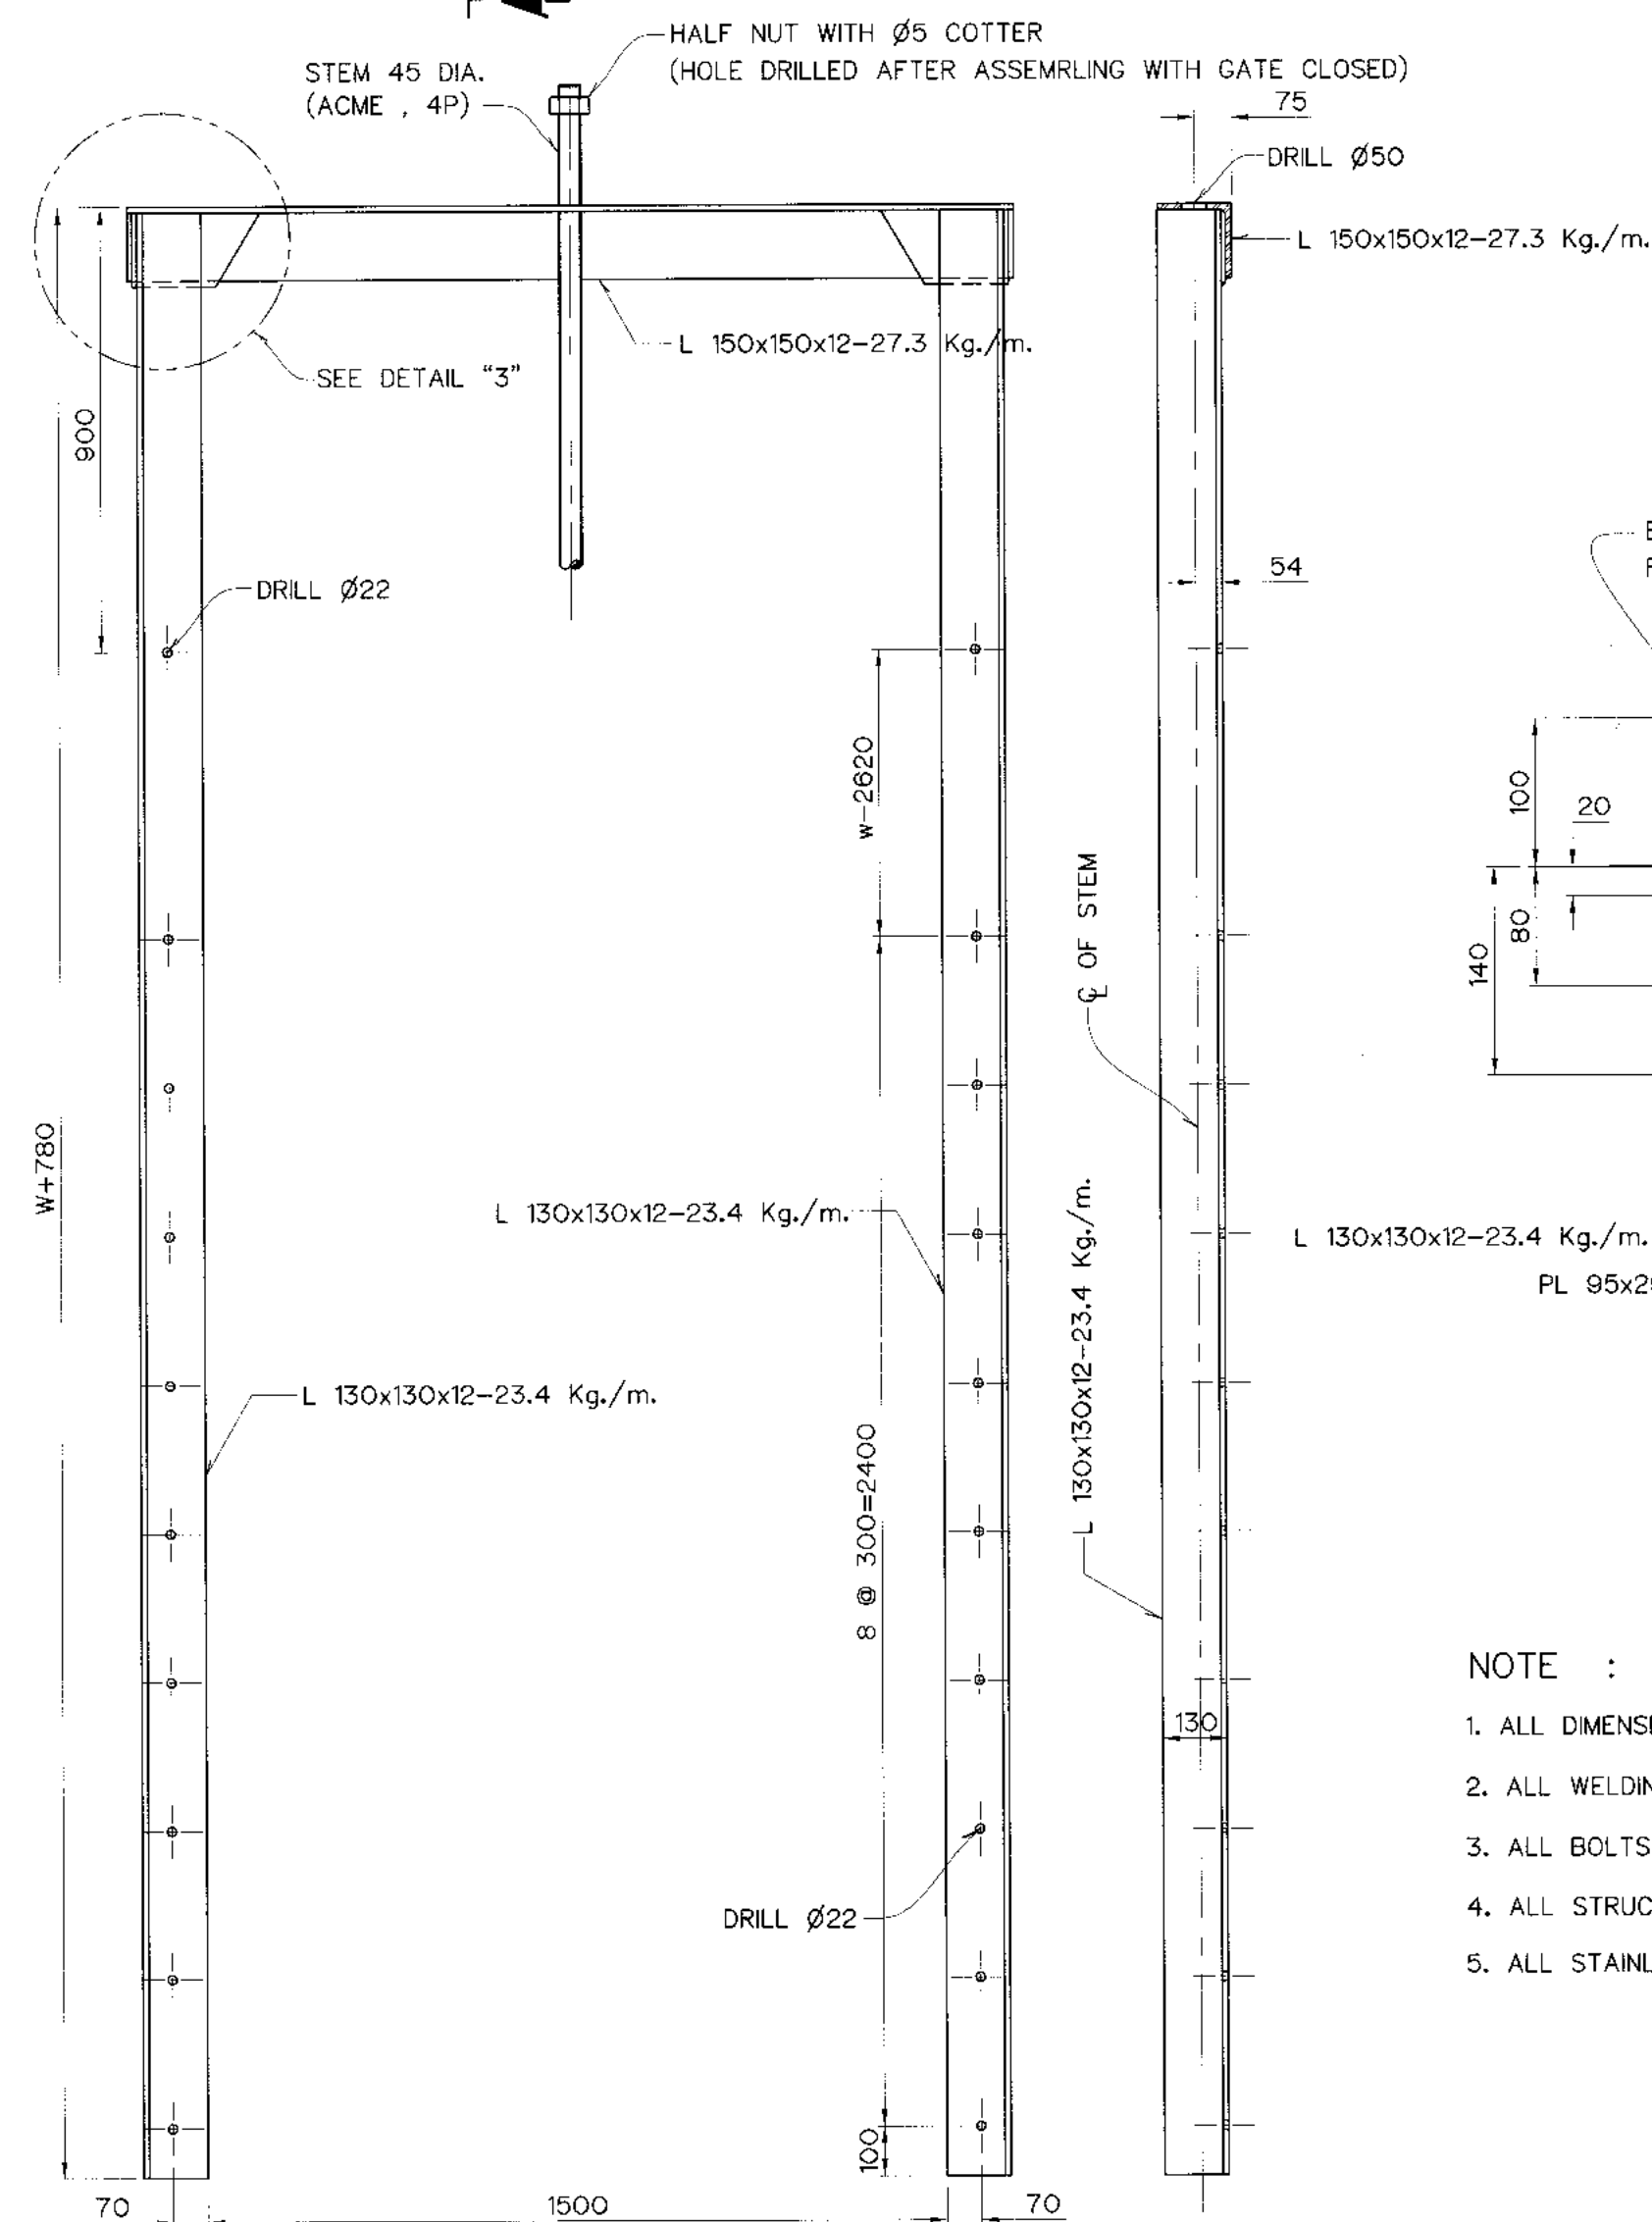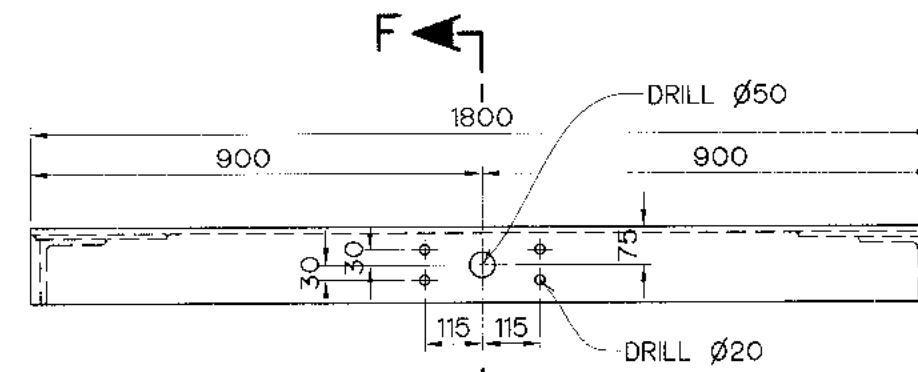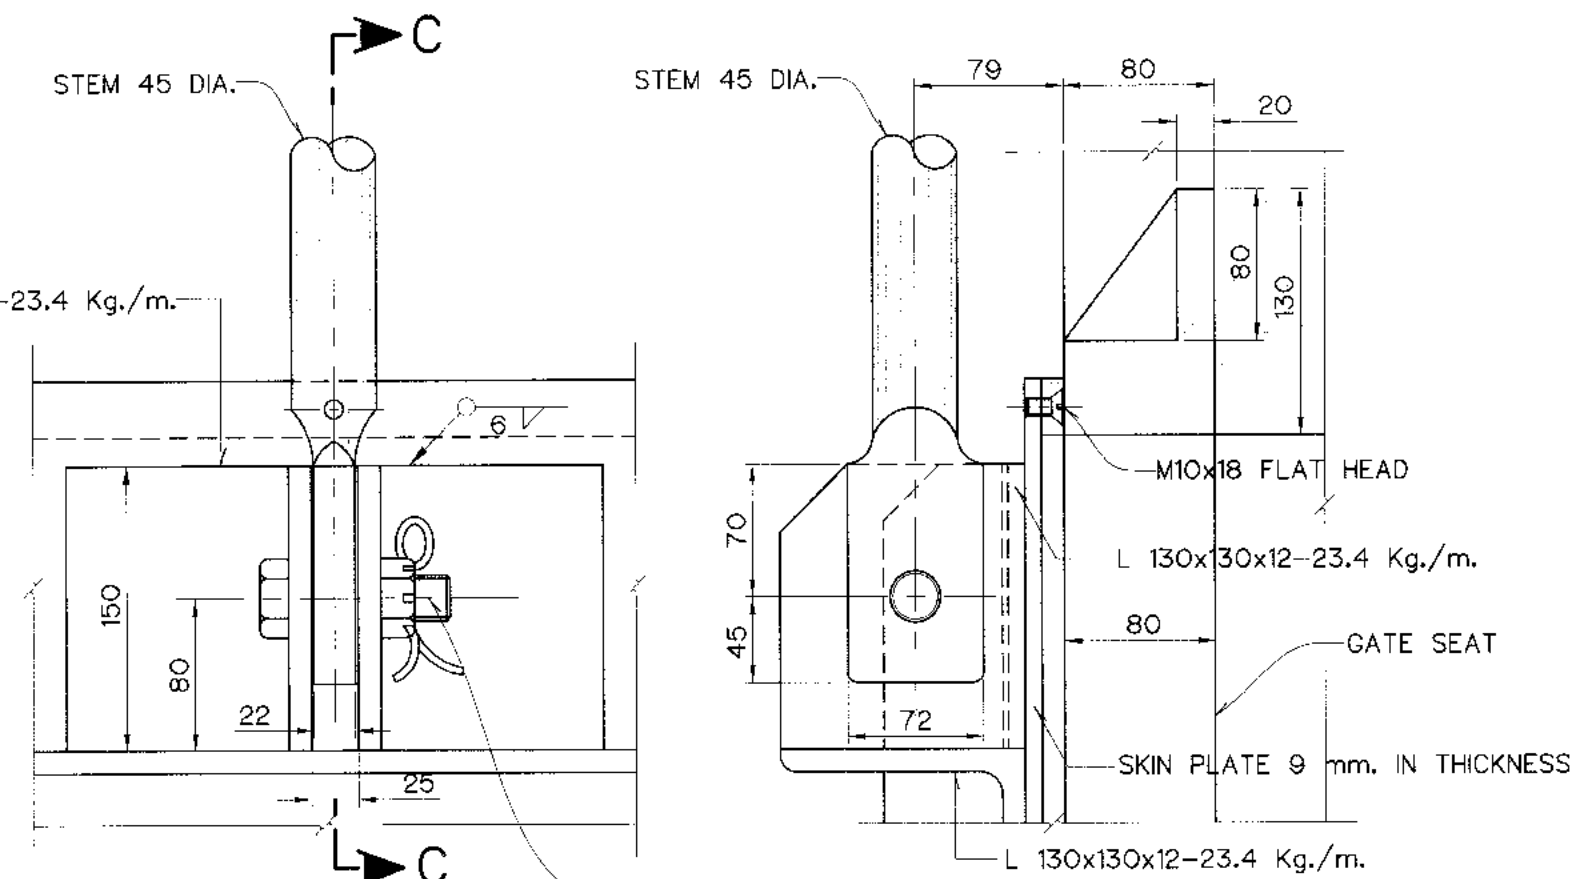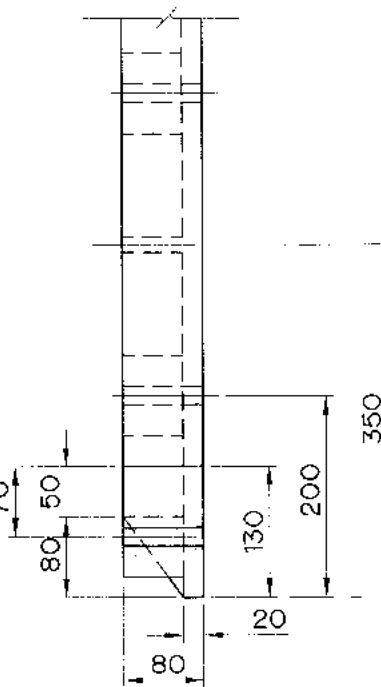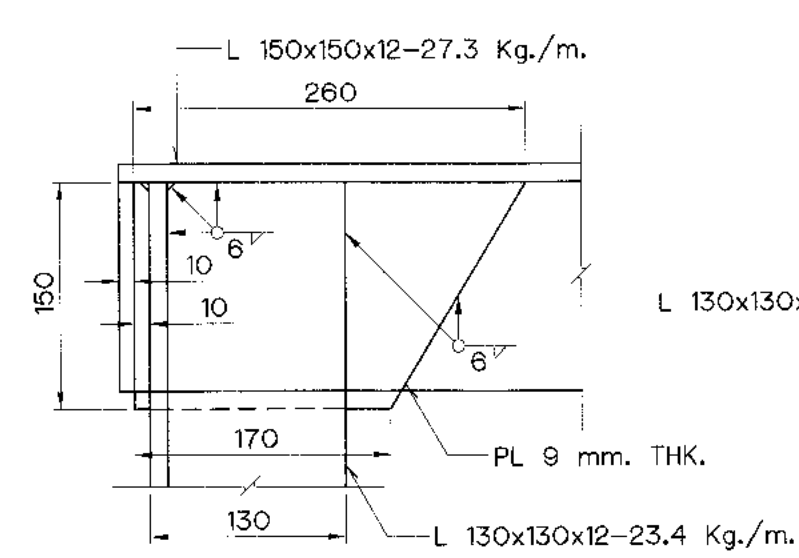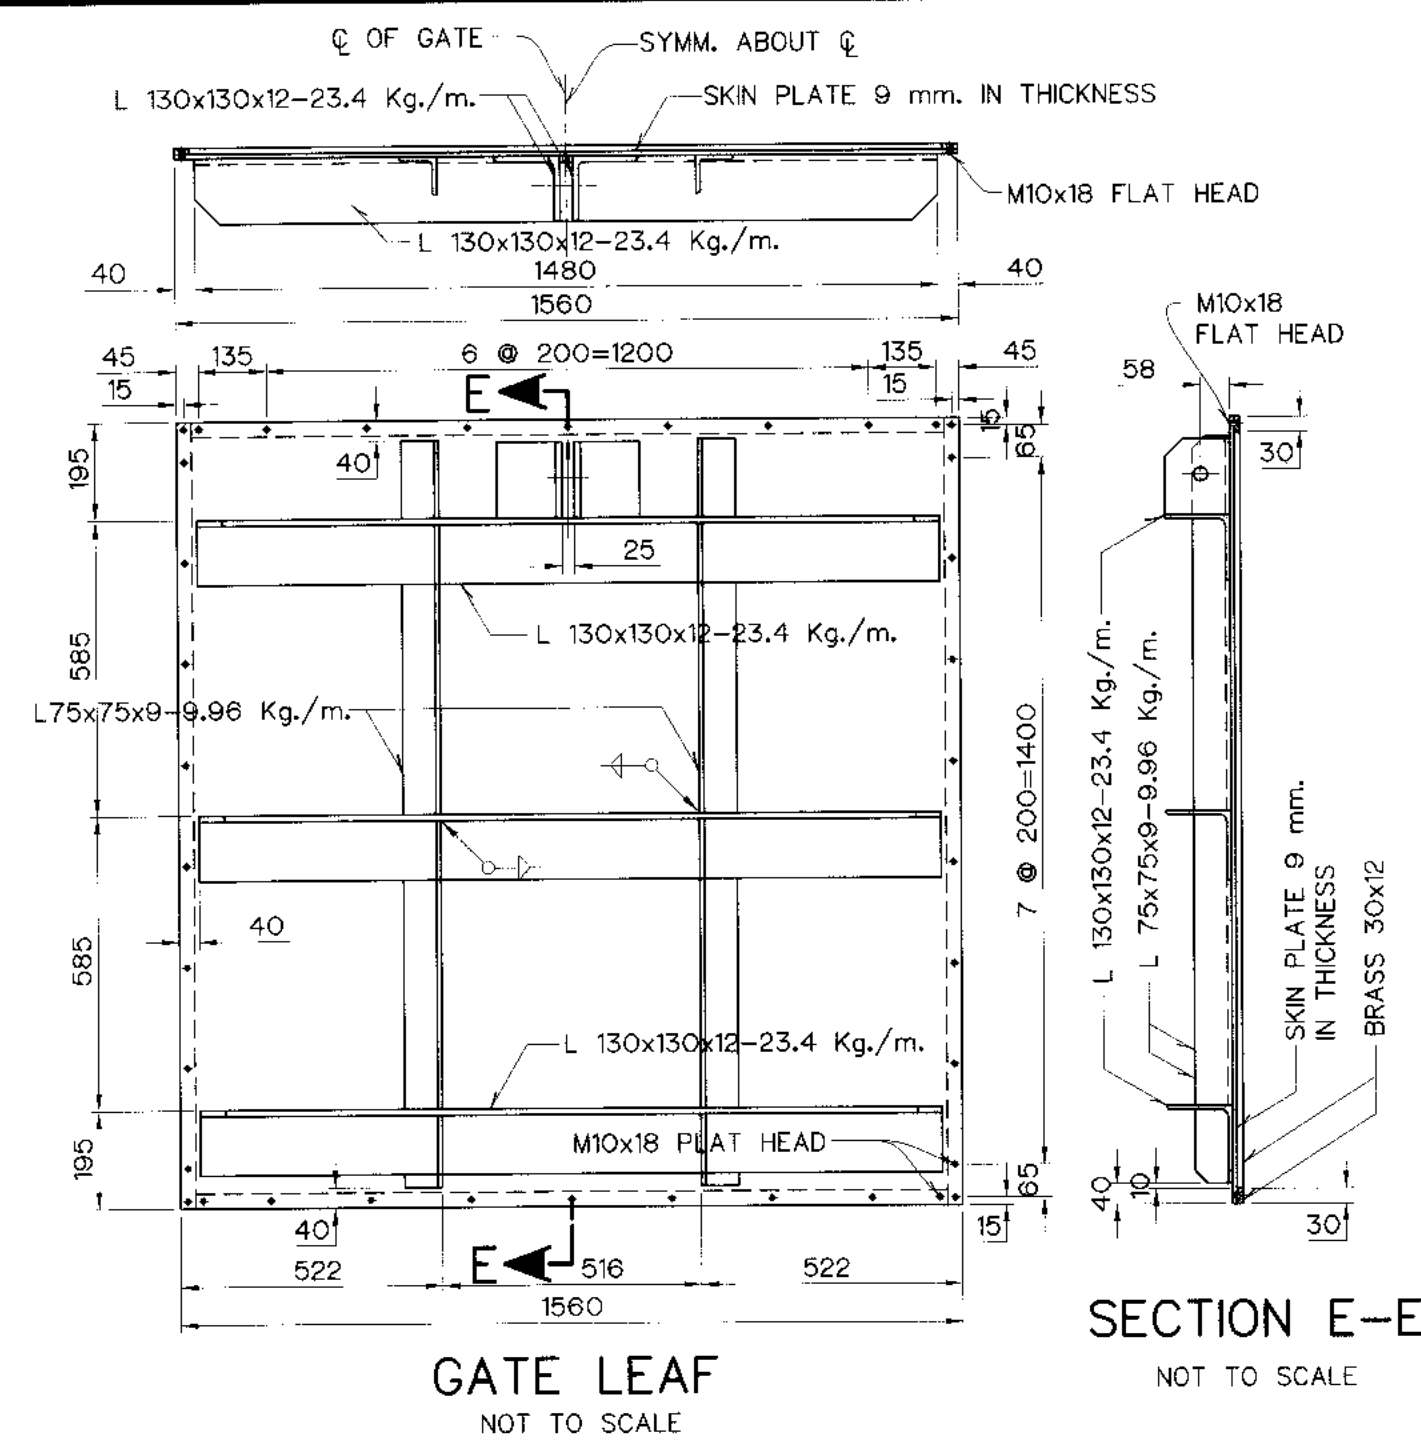


3				
2				
1				
NO.	DATE	REVISIONS	CHECKED	APPROVED
	CONSULTANTS		DEDE	

 KINGDOM OF SHAN Department of Alternative Energy Development and Efficiency MINISTRY OF ENERGY	
KLONG LAM PLOK HYDROPOWER PROJECT	
CIVIL WORKS AND TRANSMISSION LINE	
WEIR : INTAKE STRUCTURE	
DIA. 1.50 m. VERTICAL GATE	
 P&C MANAGEMENT CO.,LTD.	 Department of Alternative Energy Development and Efficiency MINISTRY OF ENERGY
DESIGNED <i>[Signature]</i> #18.29074 <i>[Signature]</i> #26.6226	REVIEWED <i>[Signature]</i>
DRAWN <i>[Signature]</i>	SUBMITTED <i>[Signature]</i>
CHECKED <i>[Signature]</i> #26.6226	RECOMMENDED <i>[Signature]</i>
<i>[Signature]</i> <i>[Signature]</i> #26.6226	APPROVED <i>[Signature]</i>
 PROJECT MANAGER	05/03/2559 DATE
KLP-WE-11	SHEET NO. 20 OF 110

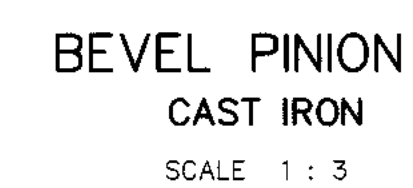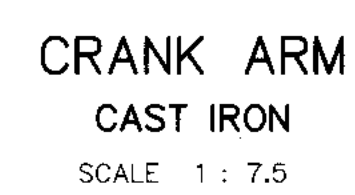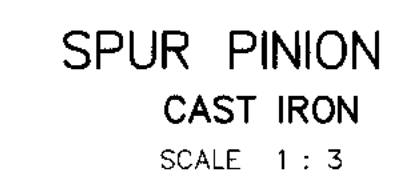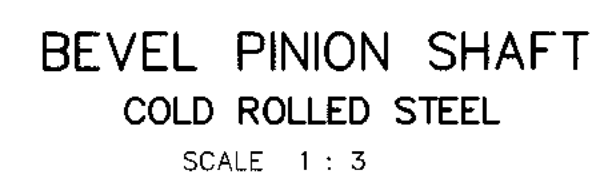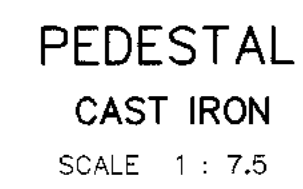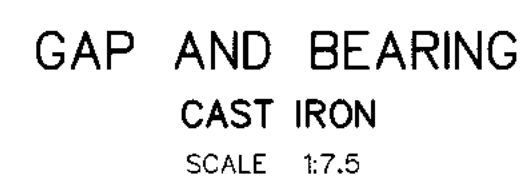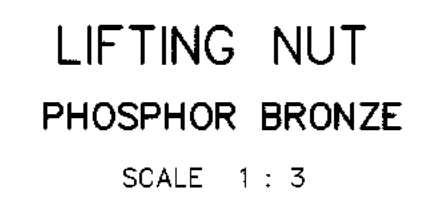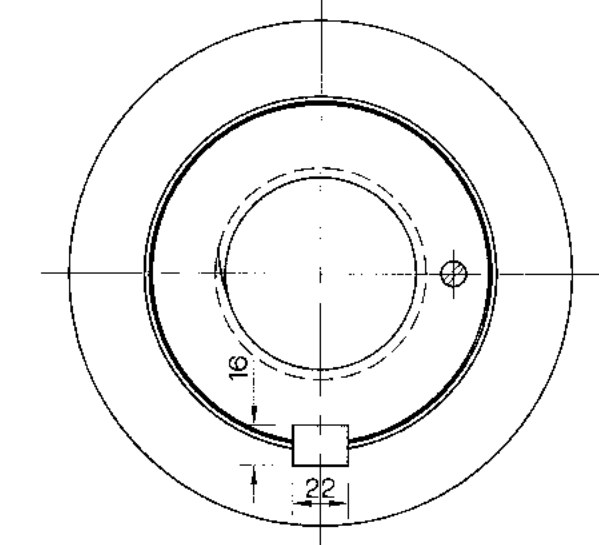 

-






 KINGDOM OF THAILAND Department of Alternative Energy Development and Efficiency MINISTRY OF ENERGY	
KLONG LAM PLOK HYDROPOWER PROJECT	
CIVIL WORKS AND TRANSMISSION LINE	
WEIR	
PEDESTAL SCREW LIFT CAPACITY 6.5 TONS	
 P&C MANAGEMENT CO.,LTD.	 Department of Alternative Energy Development and Efficiency MINISTRY OF ENERGY
DESIGNED <i>h</i> 21.29.074 21.28.6228	REVIEWED <i>Chenit</i>
DRAWN <i>Chenit</i>	SUBMITTED <i>Chenit</i>
CHECKED <i>P. Harn</i> 21.28.6228	APPROVED <i>P. Harn</i>
PROJECT MANAGER <i>OR</i> 08/03/2559 DATE	DRAWING NO. KLP-WE-12 SHEET NO. 21 OF 110

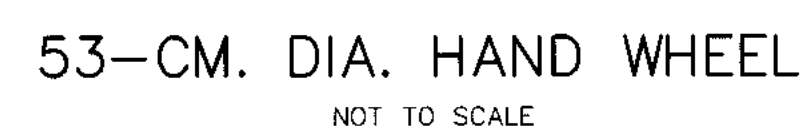



1. ALL DIMENSIONS ARE IN MILLIMETER, UNLESS OTHERWISE SHOWN.

 KINGDOM OF THAILAND Department of Alternative Energy Development and Efficiency MINISTRY OF ENERGY	
KLONG LAM PLOK HYDROPOWER PROJECT	
CIVIL WORKS AND TRANSMISSION LINE	
WEIR	
GATE-LIFT PEDESTAL AND HAND WHEEL	
 P&C MANAGEMENT CO.,LTD.	 Department of Alternative Energy Development and Efficiency MINISTRY OF ENERGY
DESIGNED <i>W</i> 28.29074 <i>W</i> 28.6226	REVIEWED <i>Handwritten signature</i>
DRAWN <i>gum X</i>	SUBMITTED <i>Handwritten signature</i>
CHECKED <i>P.V.</i> 28.6226	RECOMMENDED <i>Handwritten signature</i>
<i>OL</i> PROJECT MANAGER 08/03/2559	APPROVED <i>P. Hansa</i>
DATE	DRAWING NO. KLP-WE-13
22 OF 110	SHEET NO. 22


1
SPUR GEAR
CAST IRON
NOT TO SCALE

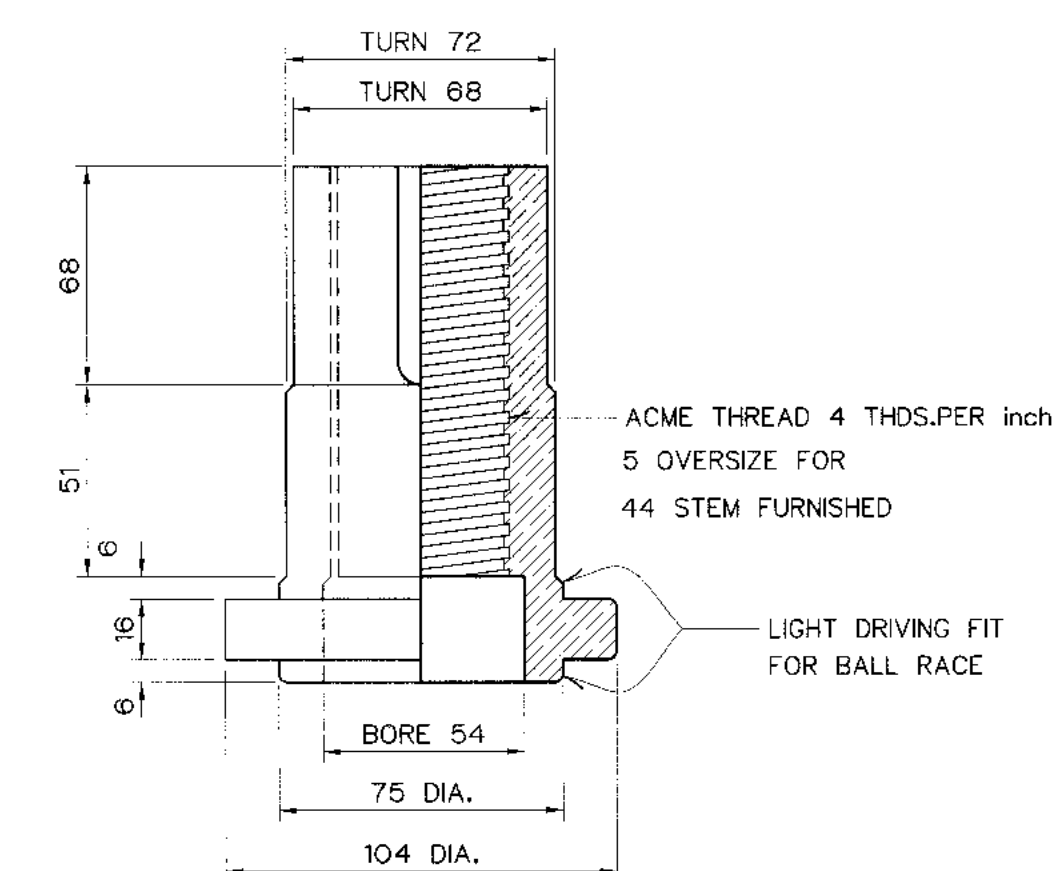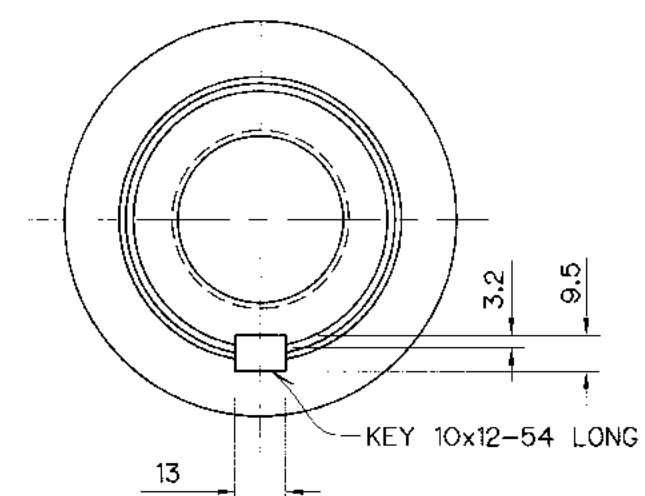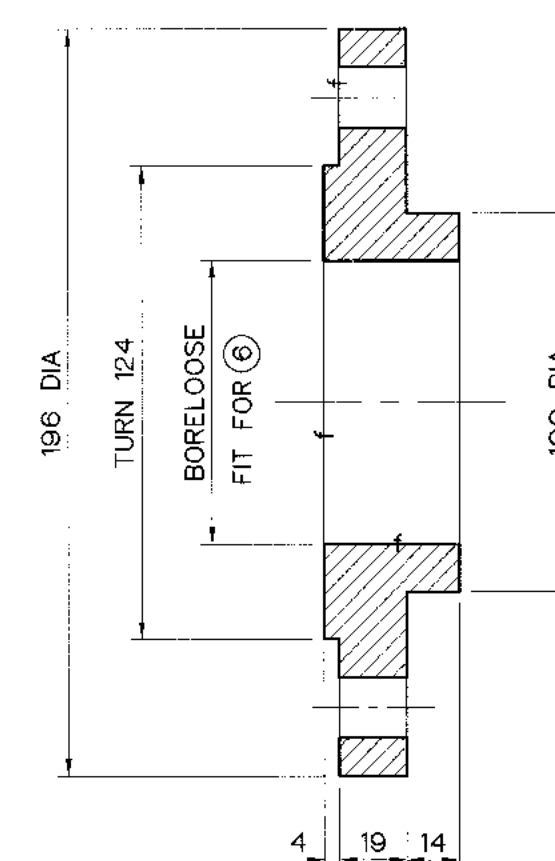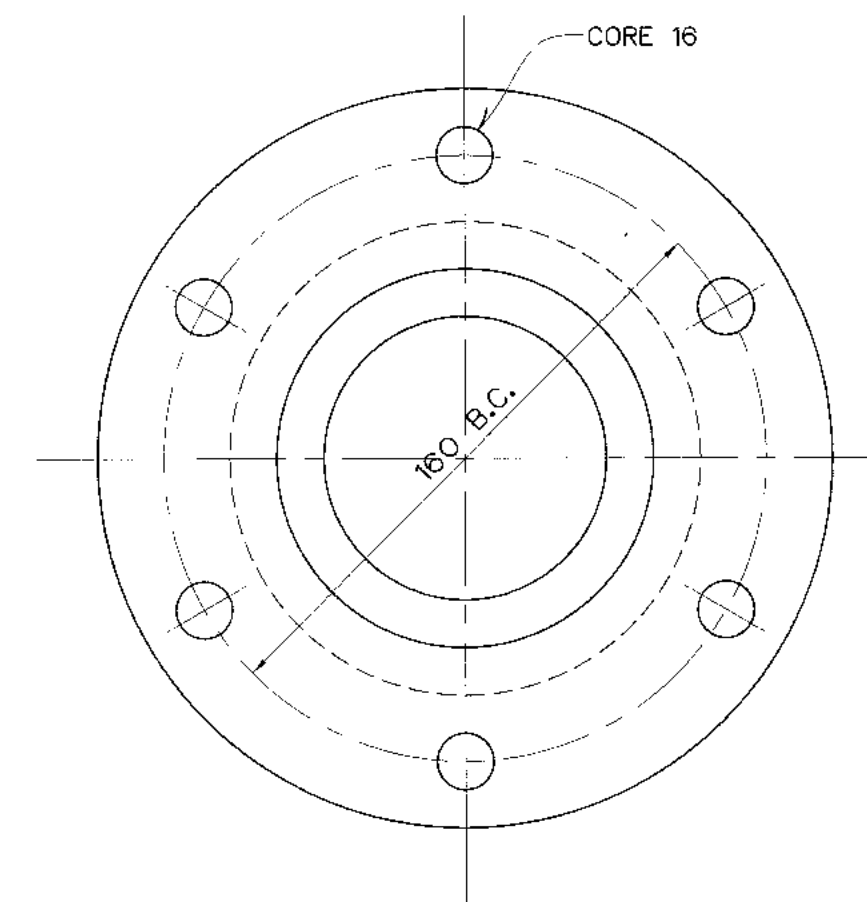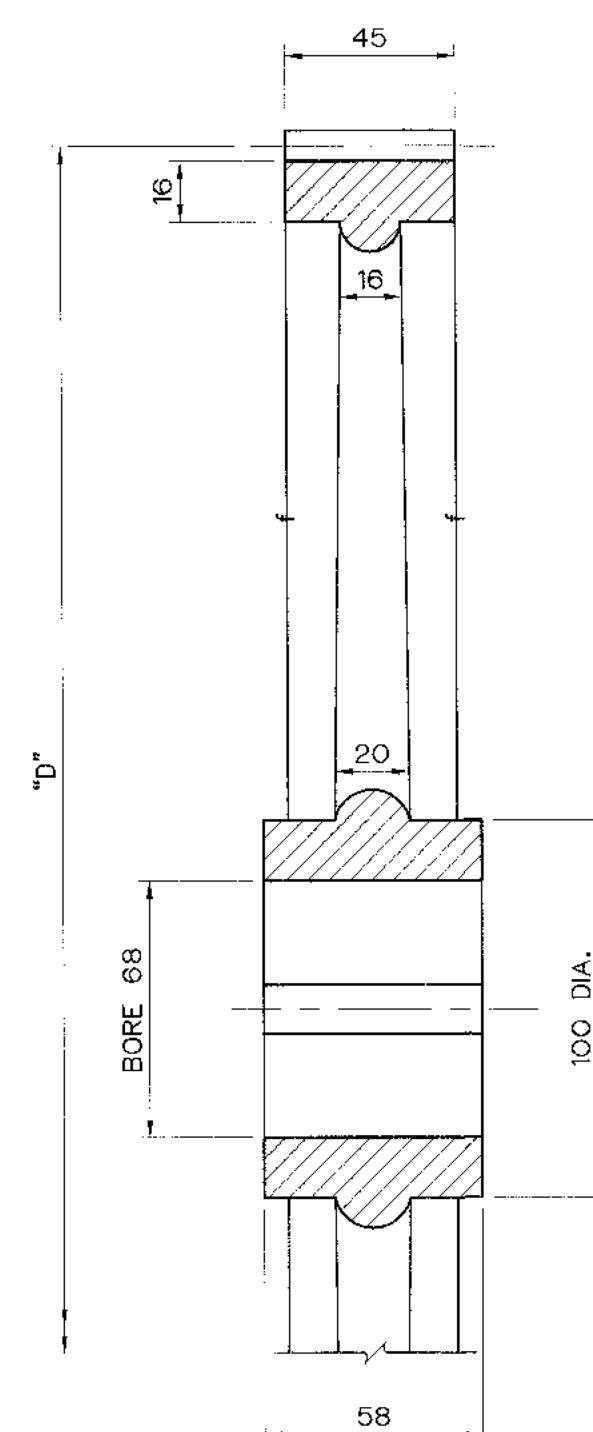

⑥
LIFTING NUT
BRONZE
NOT TO SCALE

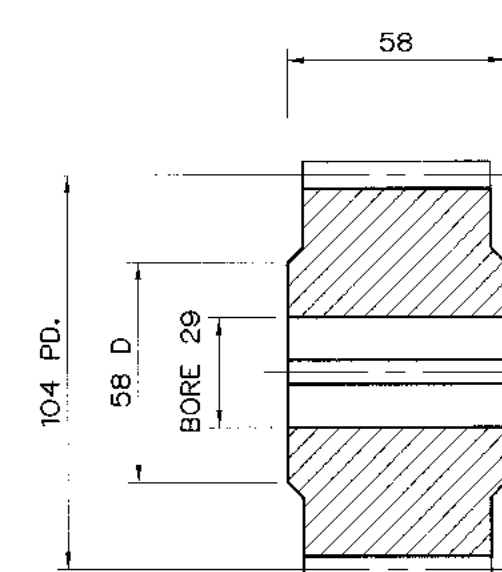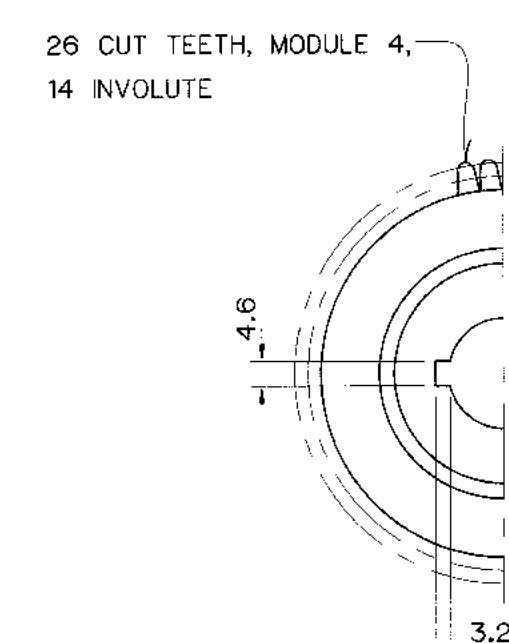



②
PINION
CAST IRON
NOT TO SCALE

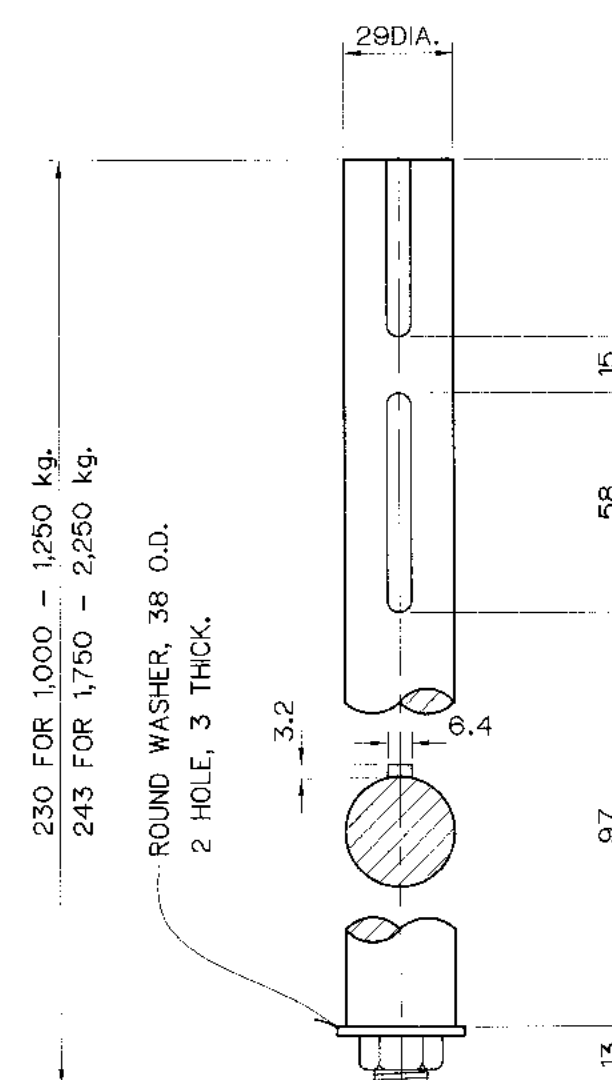


11 THDS.
CHECK M

3

PINION SHAFT
MILD STEEL
NOT TO SCALE

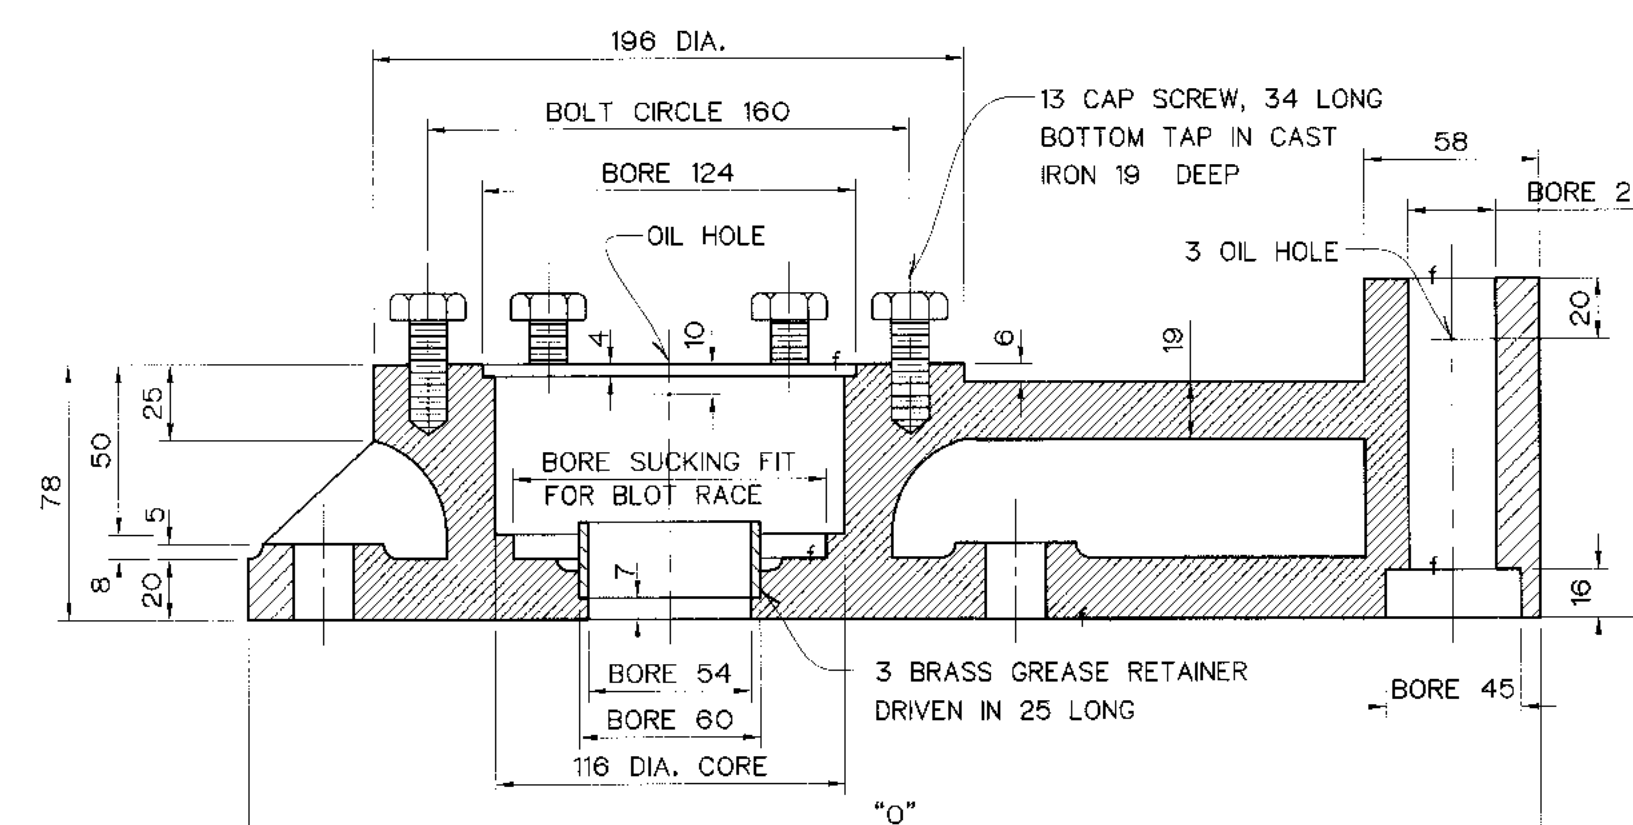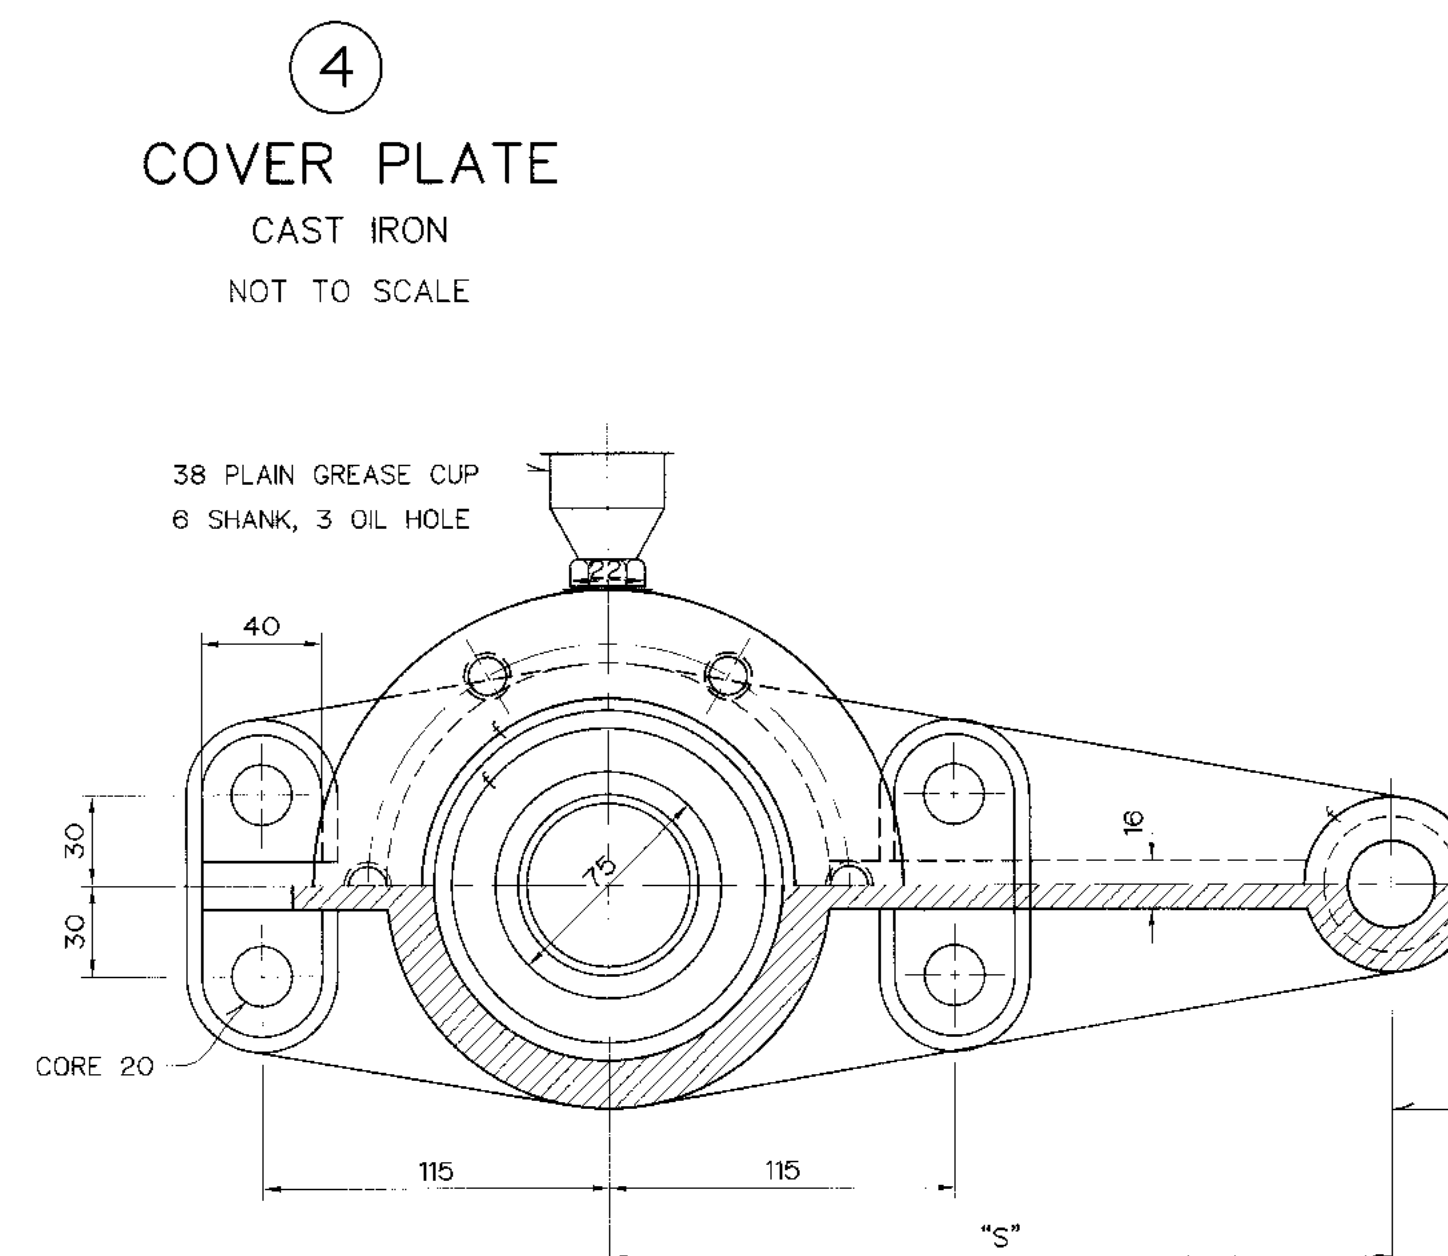

5
BASE
CAST IRON
NOT TO SCALE

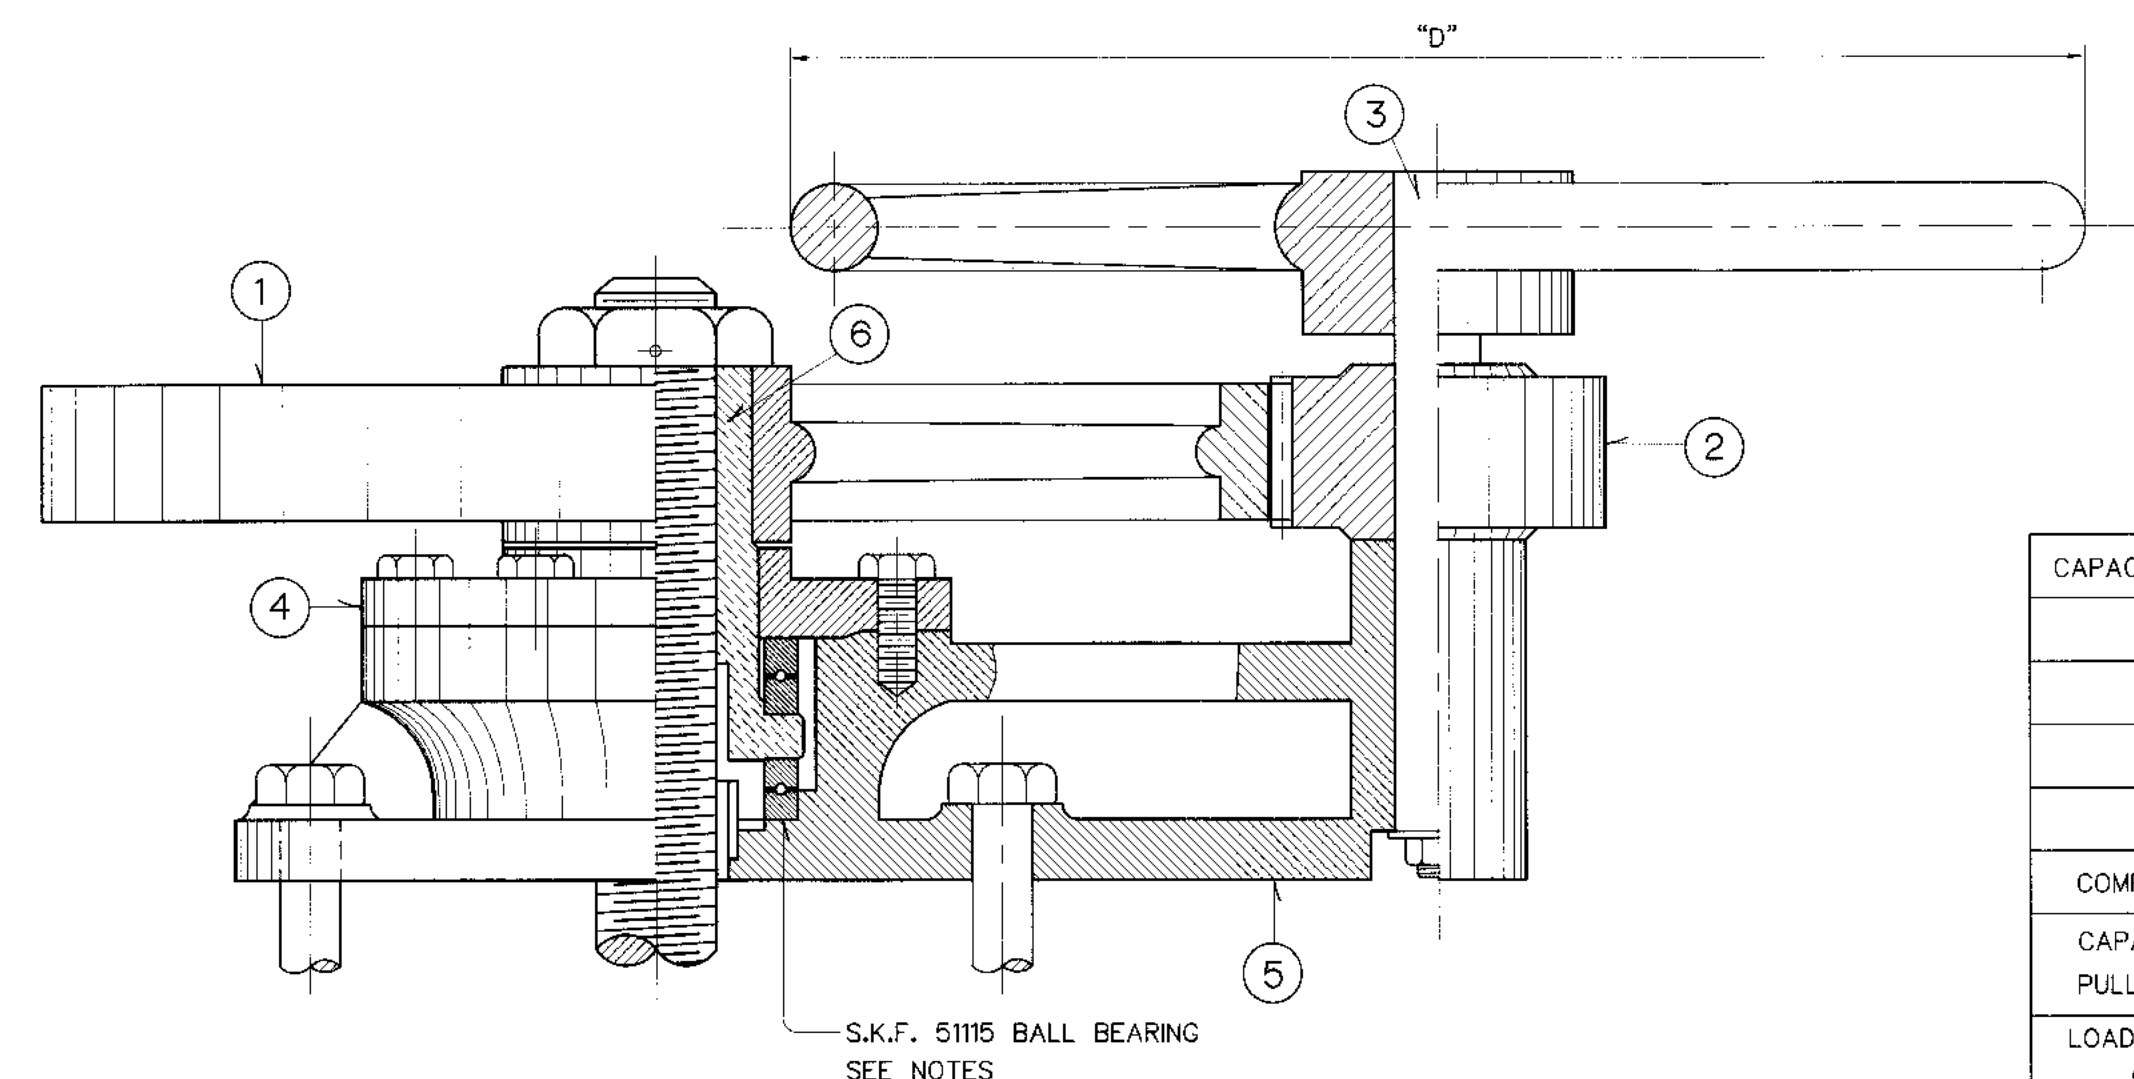

ASSEMBLY
NOT TO SCALE

CAPACITY (Kg.)	"N"	"D"	"S"	"O"	"D1"
1,000	104	416	260	429	300
1,250	104	416	260	429	380
1,750	130	520	312	481	450
2,250	143	572	338	502	530

COMPUTATION NO. SCREW LIFT I


CAPACITY IS BASED ON A HANDWHEEL
PULL OF 9 KG. (4.5 KG.PER HAND)

LOAD IS EQUAL TO
0.35xWATER PRESSUREON GATE LEAF
+ WEIGHT OF GATE AND STEM.

3				
2				
1				
NO.	DATE	REVISIONS	CHECKED	APPROVED
	CONSULTANTS		DEDE	



NOTES :

1. ALL DIMENSIONS ARE IN MILLIMETERS EXCEPT AS SHOWN
2. SINGLE - THRUST BALL BEARING S.K.F. 51115
DYNAMIC CAPACITY = 8150 LBS. (3,700 kg.)
BORE = 75
OUTSIDE DIAMETER = 100
HEIGHT = 19
3. VERTICAL SCREW LIFT LOCKING DEVICE DETAILS KLP-WE-04

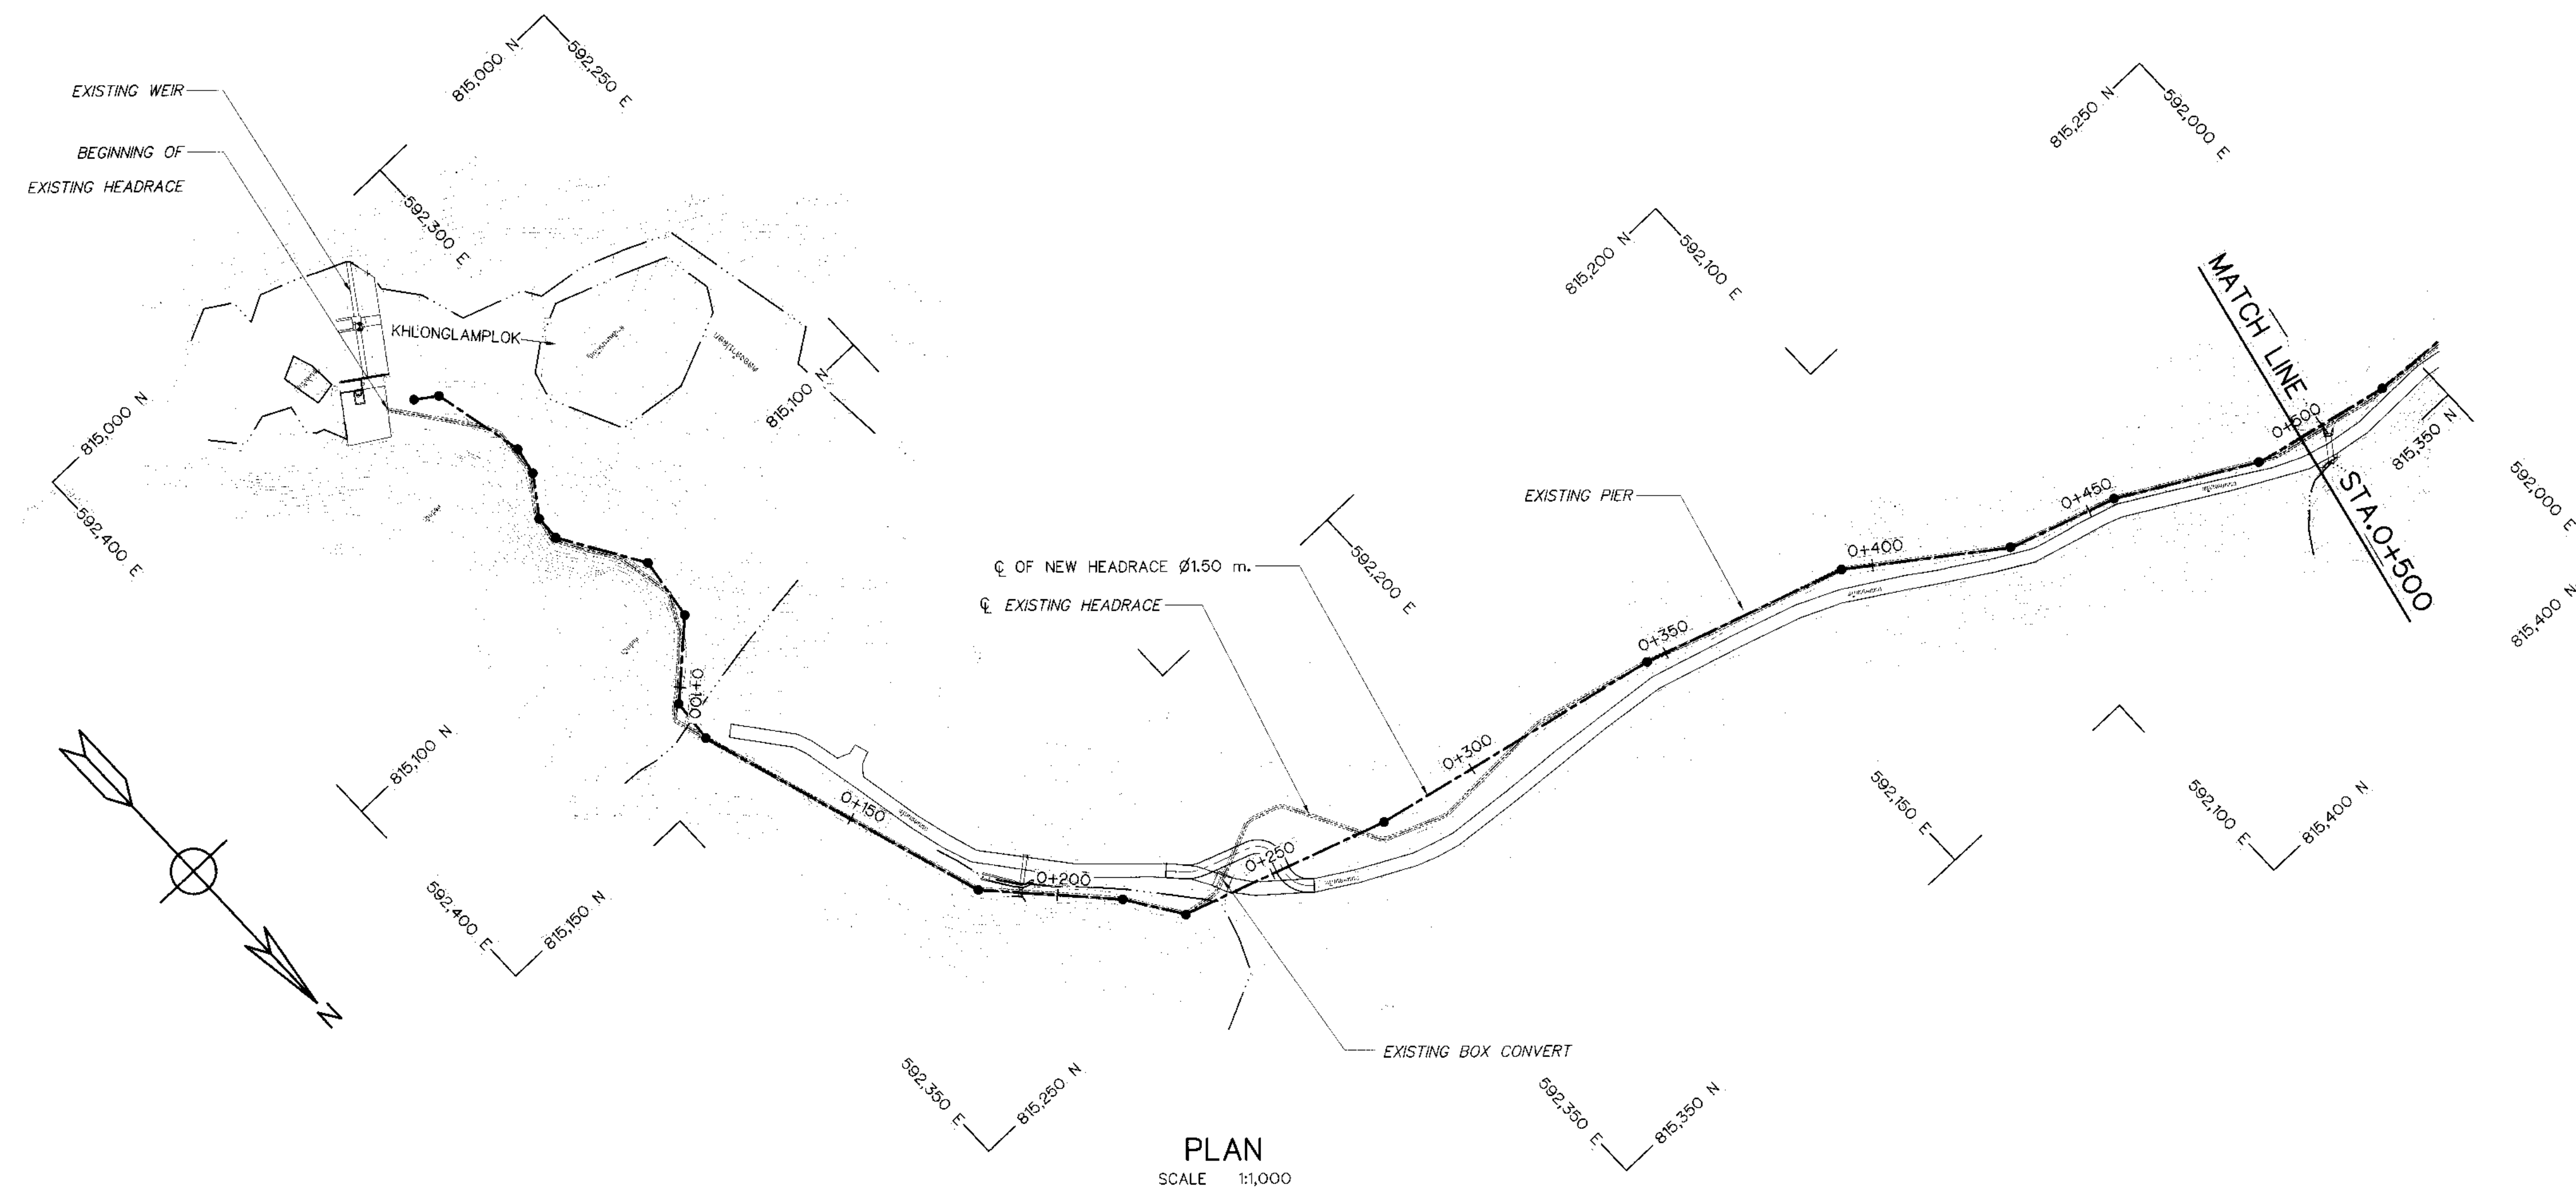

NOTES :

1. ALL DIMENSIONS AND ELEVATIONS (M.S.L.) ARE IN METERS. UNLESS OTHERWISE SHOWN.
2. SYMBOLS, ABBREVIATIONS AND GENERAL NOTES SEE DWG. NO. KLP-GN-03
3. REMOVE ALL EXISTING HEADRACE
4. EXISTING PIERS SHOULD BE DEMOLISHED AS FOLLOWS.
 - 4.1 ON HEADRACE ALIGNMENT DEMOLISH WHOLLY.
 - 4.2 OTHERWISE DEMOLISH PART OF STRUCTURES WHICH ABOVE GROUND SURFACE.

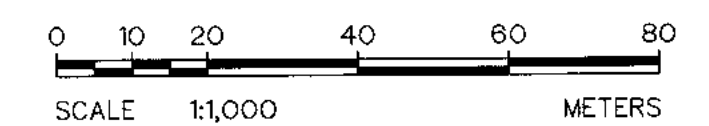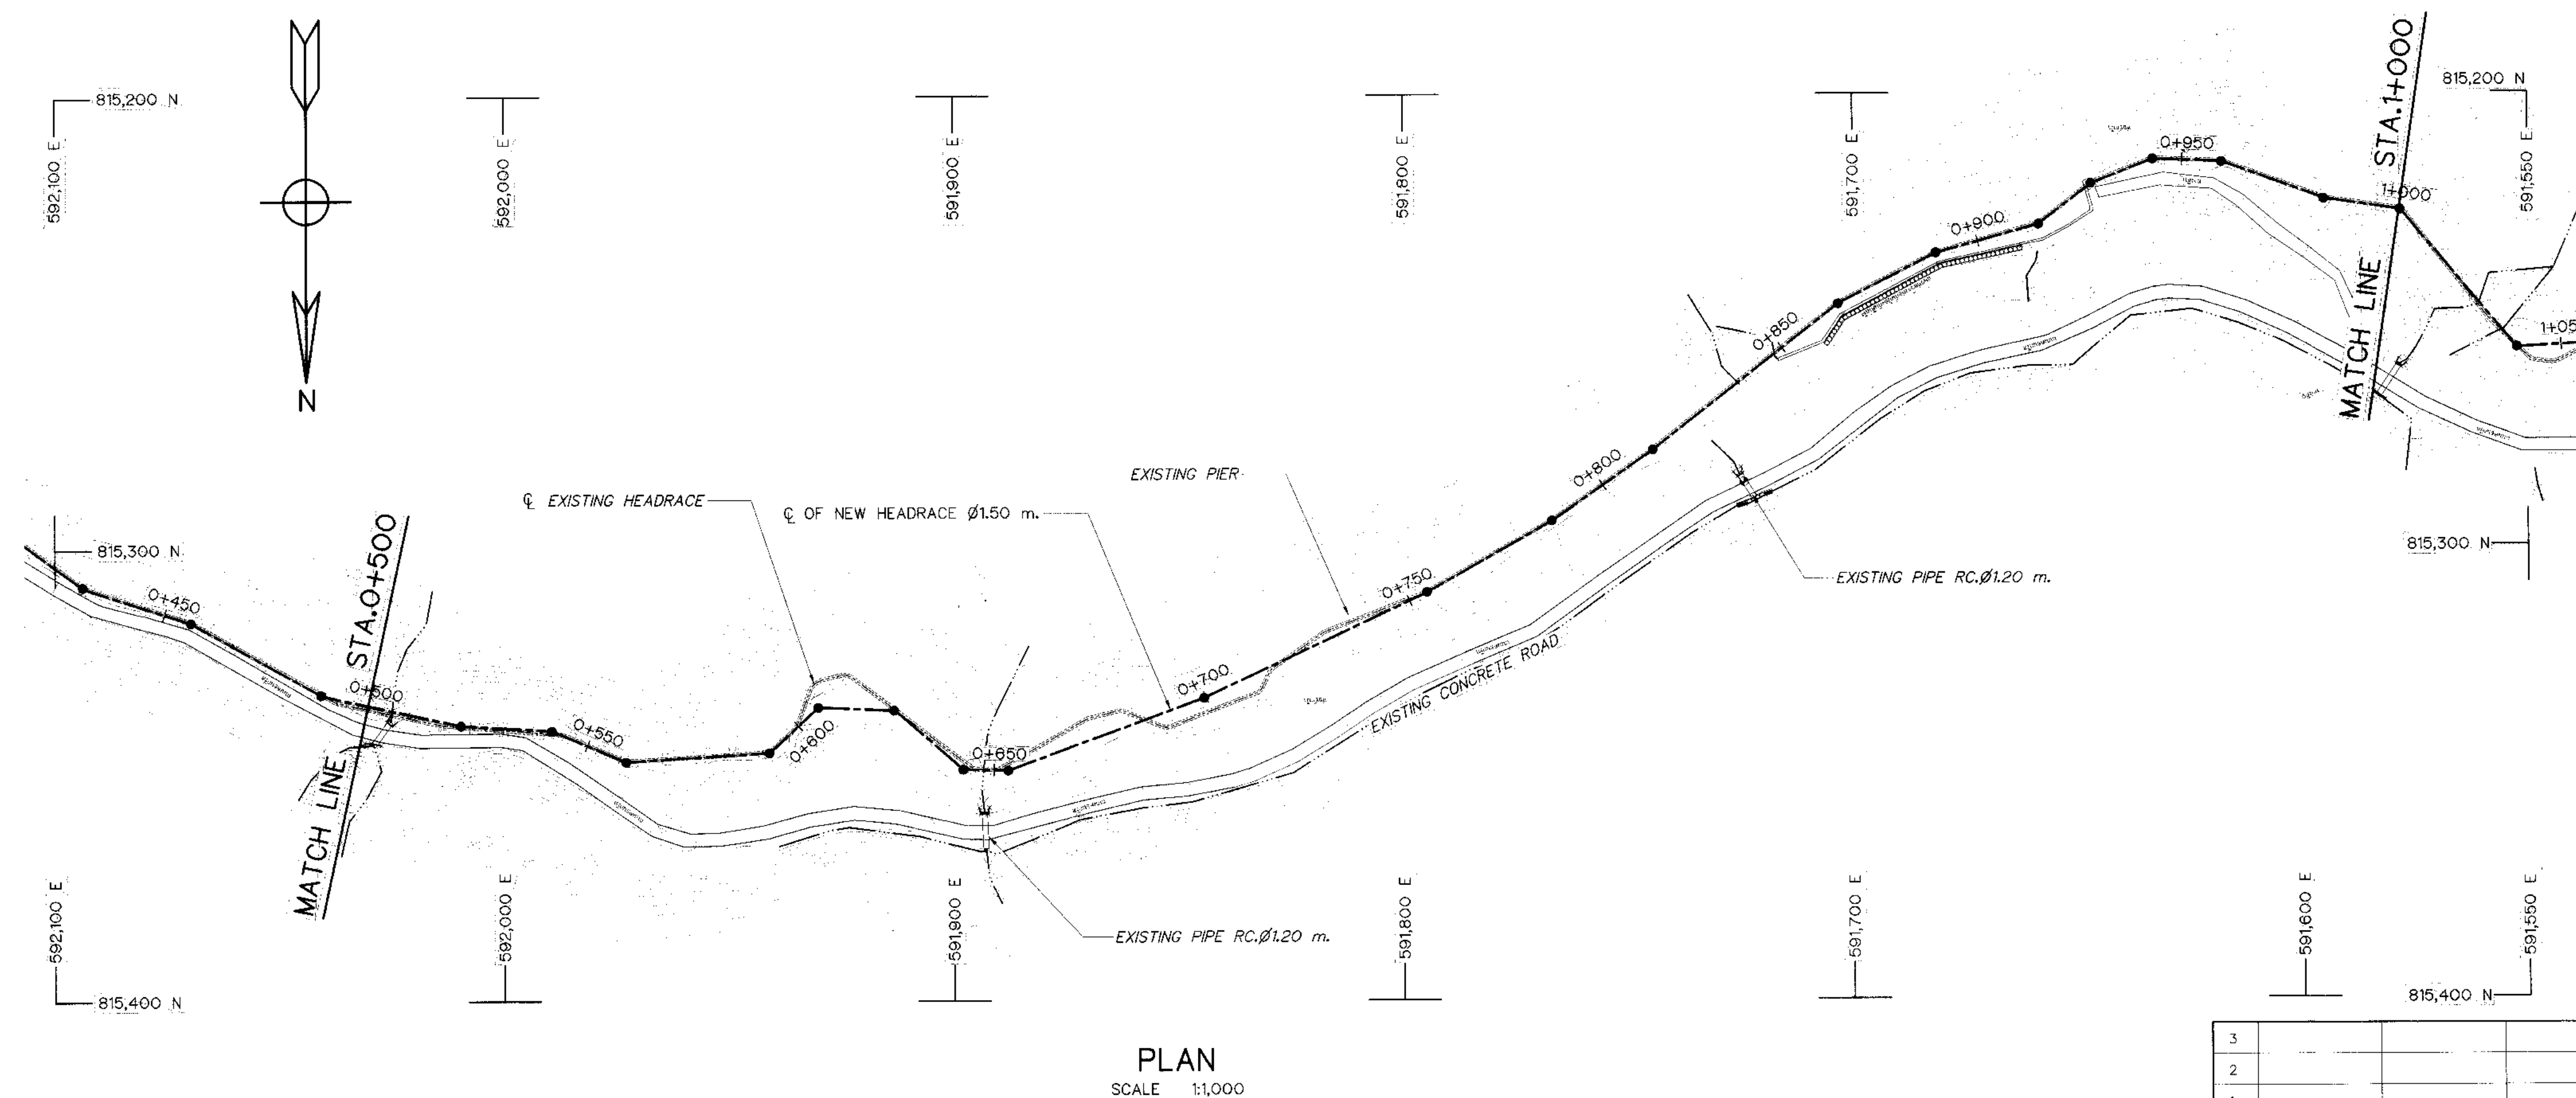

KINGDOM OF THAILAND Department of Alternative Energy Development and Efficiency MINISTRY OF ENERGY	
KLONG LAM PLOK HYDROPOWER PROJECT	
CIVIL WORKS AND TRANSMISSION LINE HEADRACE PLAN OF DEMOLITION WORK, STA. 0+000 TO STA. 1+000	
DESIGNED <i>[Signature]</i> #18.29074 DRAWN <i>[Signature]</i> CHECKED <i>[Signature]</i> PROJECT MANAGER	REVIEWED <i>[Signature]</i> SUBMITTED <i>[Signature]</i> RECOMMENDED <i>[Signature]</i> APPROVED <i>[Signature]</i> DATE
NO. DATE REVISIONS CHECKED APPROVED CONSULTANTS DEDE	DRAWING NO. KLP-HR-01 SHEET NO. 24 OF 110


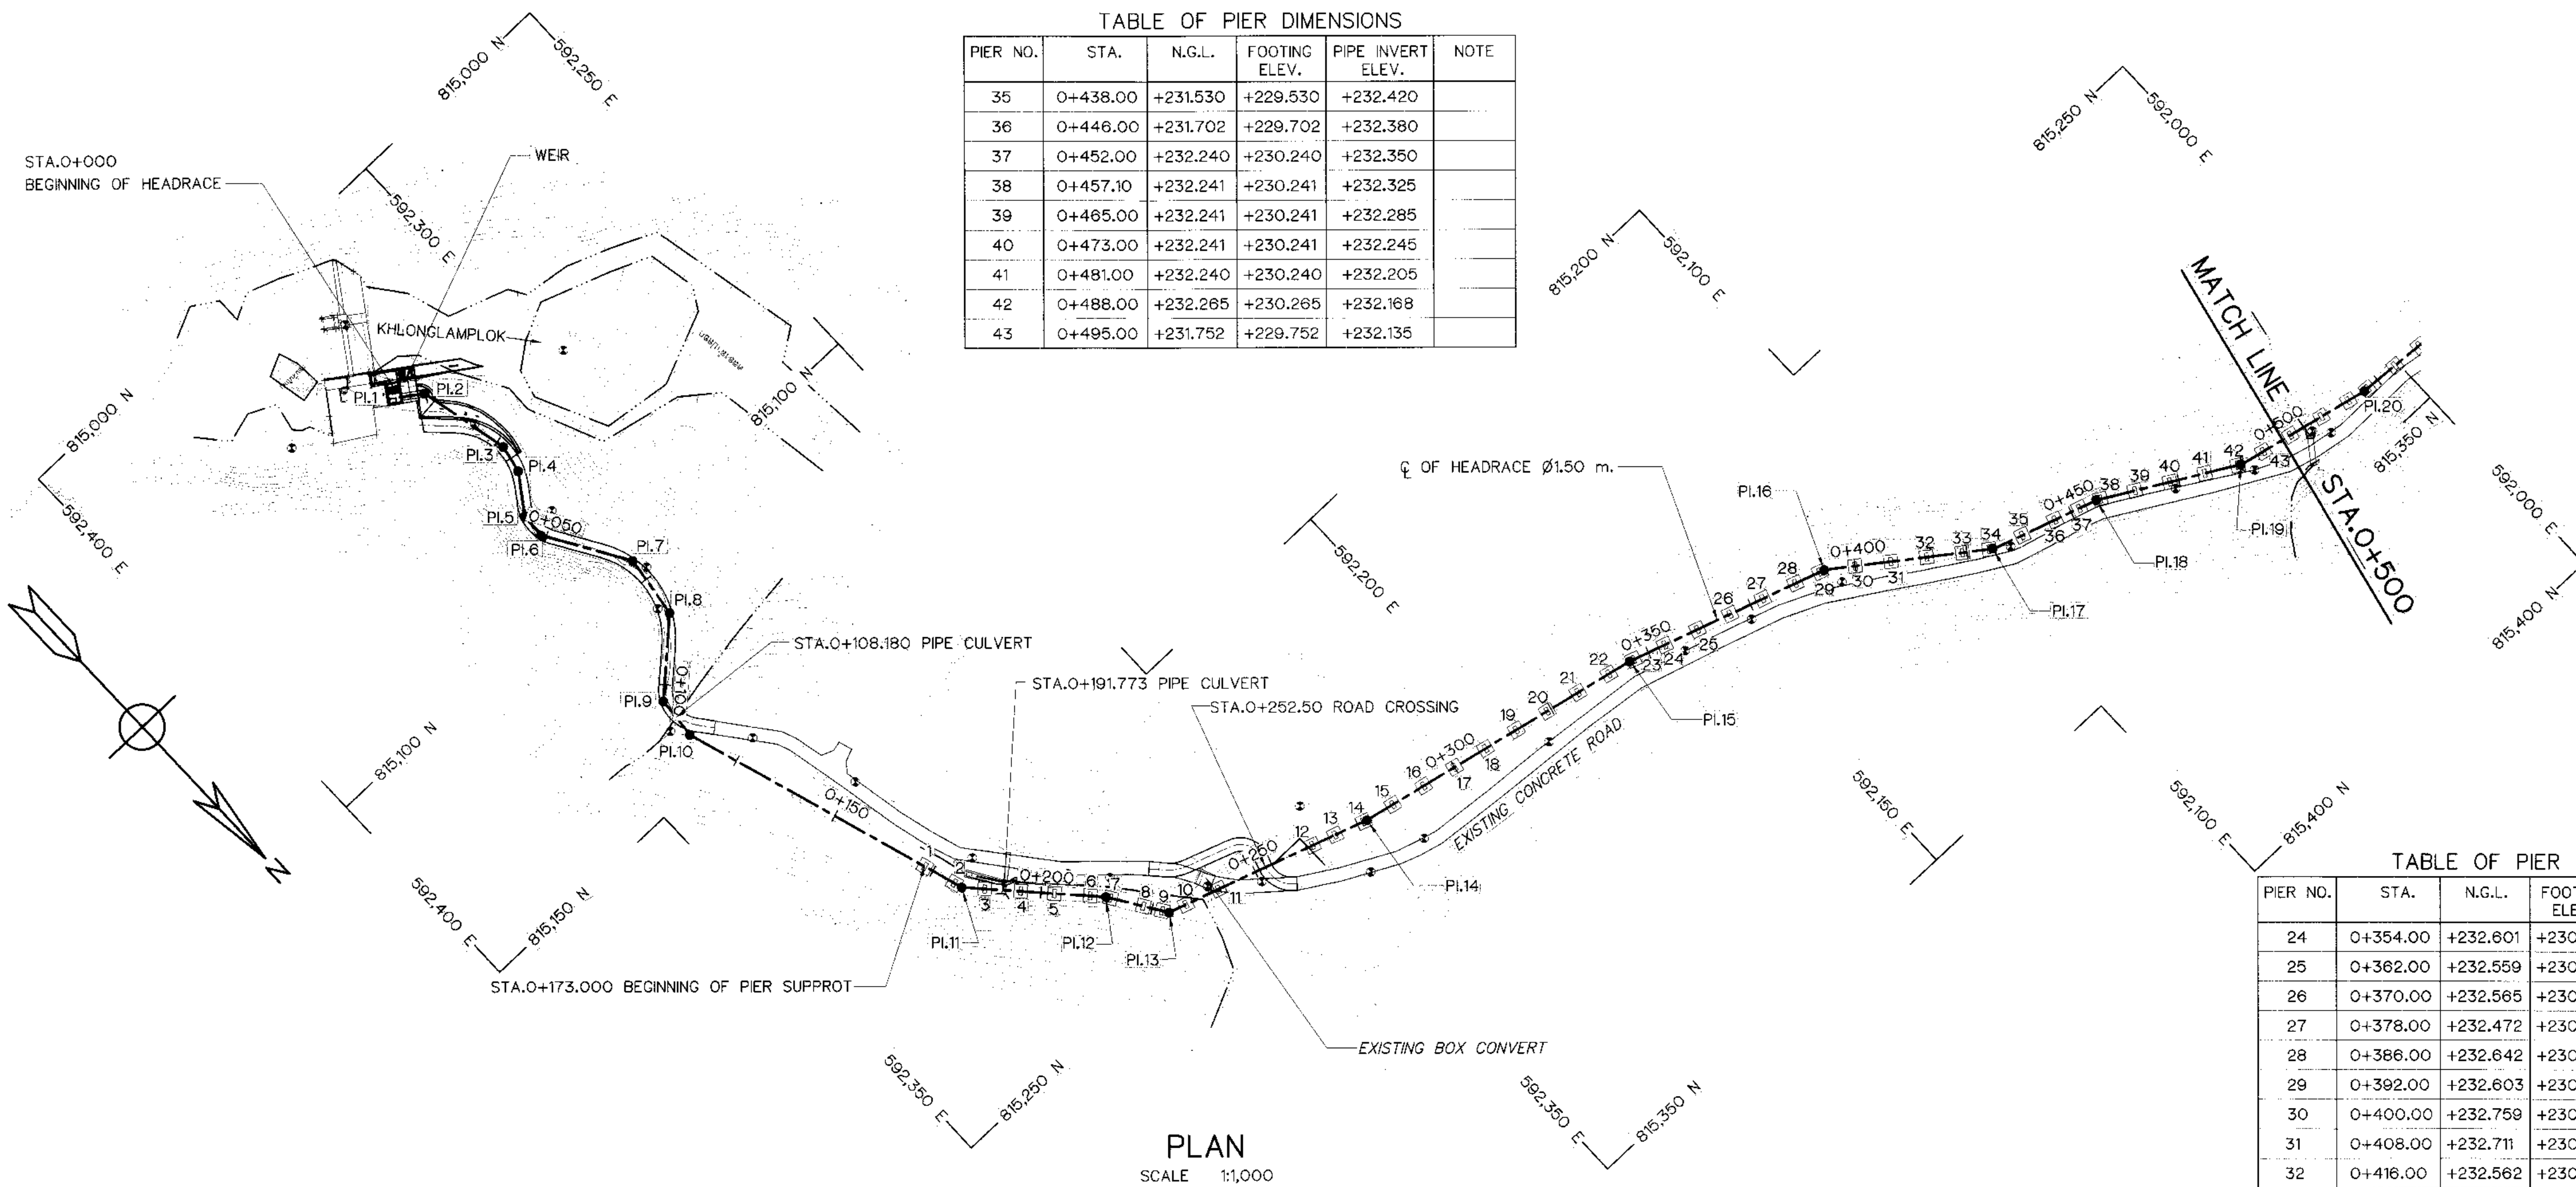


TABLE OF PIER DIMENSIONS					
PIER NO.	STA.	N.G.L.	FOOTING ELEV.	PIPE INVERT ELEV.	NOTE
35	0+438.00	+231.530	+229.530	+232.420	
36	0+446.00	+231.702	+229.702	+232.380	
37	0+452.00	+232.240	+230.240	+232.350	
38	0+457.10	+232.241	+230.241	+232.325	
39	0+465.00	+232.241	+230.241	+232.285	
40	0+473.00	+232.241	+230.241	+232.245	
41	0+481.00	+232.240	+230.240	+232.205	
42	0+488.00	+232.265	+230.265	+232.168	
43	0+495.00	+231.752	+228.752	+232.135	

HORIZONTAL CURVE OF HEADRACE					
NO. PI.	COORDINATE OF PI.		PI. TO PI. (m)	DEFLECTION ANGLE (°) (° - ' - ")	PI. STA. (km)
	N	E			
PI.1	815,041.962	592,329.225	-	-	0+000.000
PI.2	815,045.138	592,324.588	5.620	42°-52'-16.47"	0+005.620
PI.3	815,065.755	592,319.934	21.136	24°-04'-30.97"	0+026.756
PI.4	815,071.900	592,321.168	6.268	24°-03'-58.27"	0+033.024
PI.5	815,080.176	592,327.054	10.156	33°-31'-04.51"	0+043.180
PI.6	815,085.774	592,327.240	5.601	33°-30'-59.62"	0+048.781
PI.7	815,103.765	592,316.168	21.126	39°-23'-08.39"	0+069.907
PI.8	815,117.737	592,318.073	14.102	39°-23'-01.20"	0+084.009
PI.9	815,131.082	592,332.462	19.625	42°-35'-10.90"	0+103.634
PI.10	815,140.704	592,333.231	9.653	22°-17'-35.84"	0+113.287
PI.11	815,206.552	592,312.186	69.129	25°-25'-45.91"	0+182.416
PI.12	815,230.003	592,290.200	32.148	09°-50'-43.16"	0+214.562
PI.13	815,241.994	592,282.321	14.348	38°-25'-03.47"	0+228.910
PI.14	815,257.176	592,236.346	48.417	06°-14'-50.45"	0+277.327
PI.15	815,271.366	592,189.742	88.099	05°-57'-25.72"	0+345.426
PI.16	815,286.098	592,124.359	47.714	17°-56'-04.34"	0+393.140
PI.17	815,308.369	592,093.614	37.964	18°-02'-49.34"	0+431.104
PI.18	815,316.089	592,069.672	25.156	11°-12'-39.17"	0+456.260
PI.19	815,332.331	592,040.470	33.415	16°-54'-59.98"	0+489.675

TABLE OF PIER DIMENSIONS					
PIER NO.	STA.	N.G.L.	FOOTING ELEV.	PIPE INVERT ELEV.	NOTE
24	0+354.00	+232.601	+230.601	+232.840	
25	0+362.00	+232.559	+230.559	+232.800	
26	0+370.00	+232.565	+230.565	+232.760	
27	0+378.00	+232.472	+230.472	+232.720	
28	0+386.00	+232.642	+230.642	+232.680	
29	0+392.00	+232.603	+230.603	+232.650	
30	0+400.00	+232.759	+230.759	+232.610	
31	0+408.00	+232.711	+230.711	+232.570	
32	0+416.00	+232.562	+230.562	+232.530	
33	0+424.00	+232.609	+230.609	+232.490	
34	0+430.00	+232.260	+230.260	+232.460	

TABLE OF PIER DIMENSIONS					
PIER NO.	STA.	N.G.L.	FOOTING ELEV.	PIPE INVERT ELEV.	NOTE
1	0+173.00	+234.481	+234.481	+233.454	
2	0+180.50	+233.658	+231.658	+233.439	
3	0+187.50	+233.479	+231.479	+233.425	
4	0+195.50	+233.472	+231.472	+233.409	
5	0+203.00	+233.573	+231.573	+233.394	
6	0+211.00	+233.573	+231.573	+233.378	
7	0+215.50	+233.573	+231.573	+233.369	
8	0+223.00	+233.703	+231.703	+233.354	
9	0+227.30	+233.793	+231.793	+233.345	
10	0+233.00	+234.000	+232.000	+233.334	
11	0+241.00	+235.312	+233.312	+233.318	
12	0+264.00	+235.312	+233.312	+233.272	
13	0+269.00	+234.382	+232.382	+233.261	
14	0+276.00	+233.378	+231.378	+233.228	
15	0+284.00	+232.796	+230.796	+233.190	
16	0+292.00	+232.472	+230.472	+233.150	
17	0+300.00	+232.484	+230.484	+233.110	
18	0+308.00	+232.426	+230.423	+233.070	
19	0+316.00	+232.426	+230.426	+233.070	
20	0+324.00	+232.832	+230.832	+232.990	
21	0+332.00	+232.739	+230.739	+232.950	
22	0+340.00	+232.679	+230.679	+232.910	
23	0+346.00	+232.655	+230.655	+232.878	

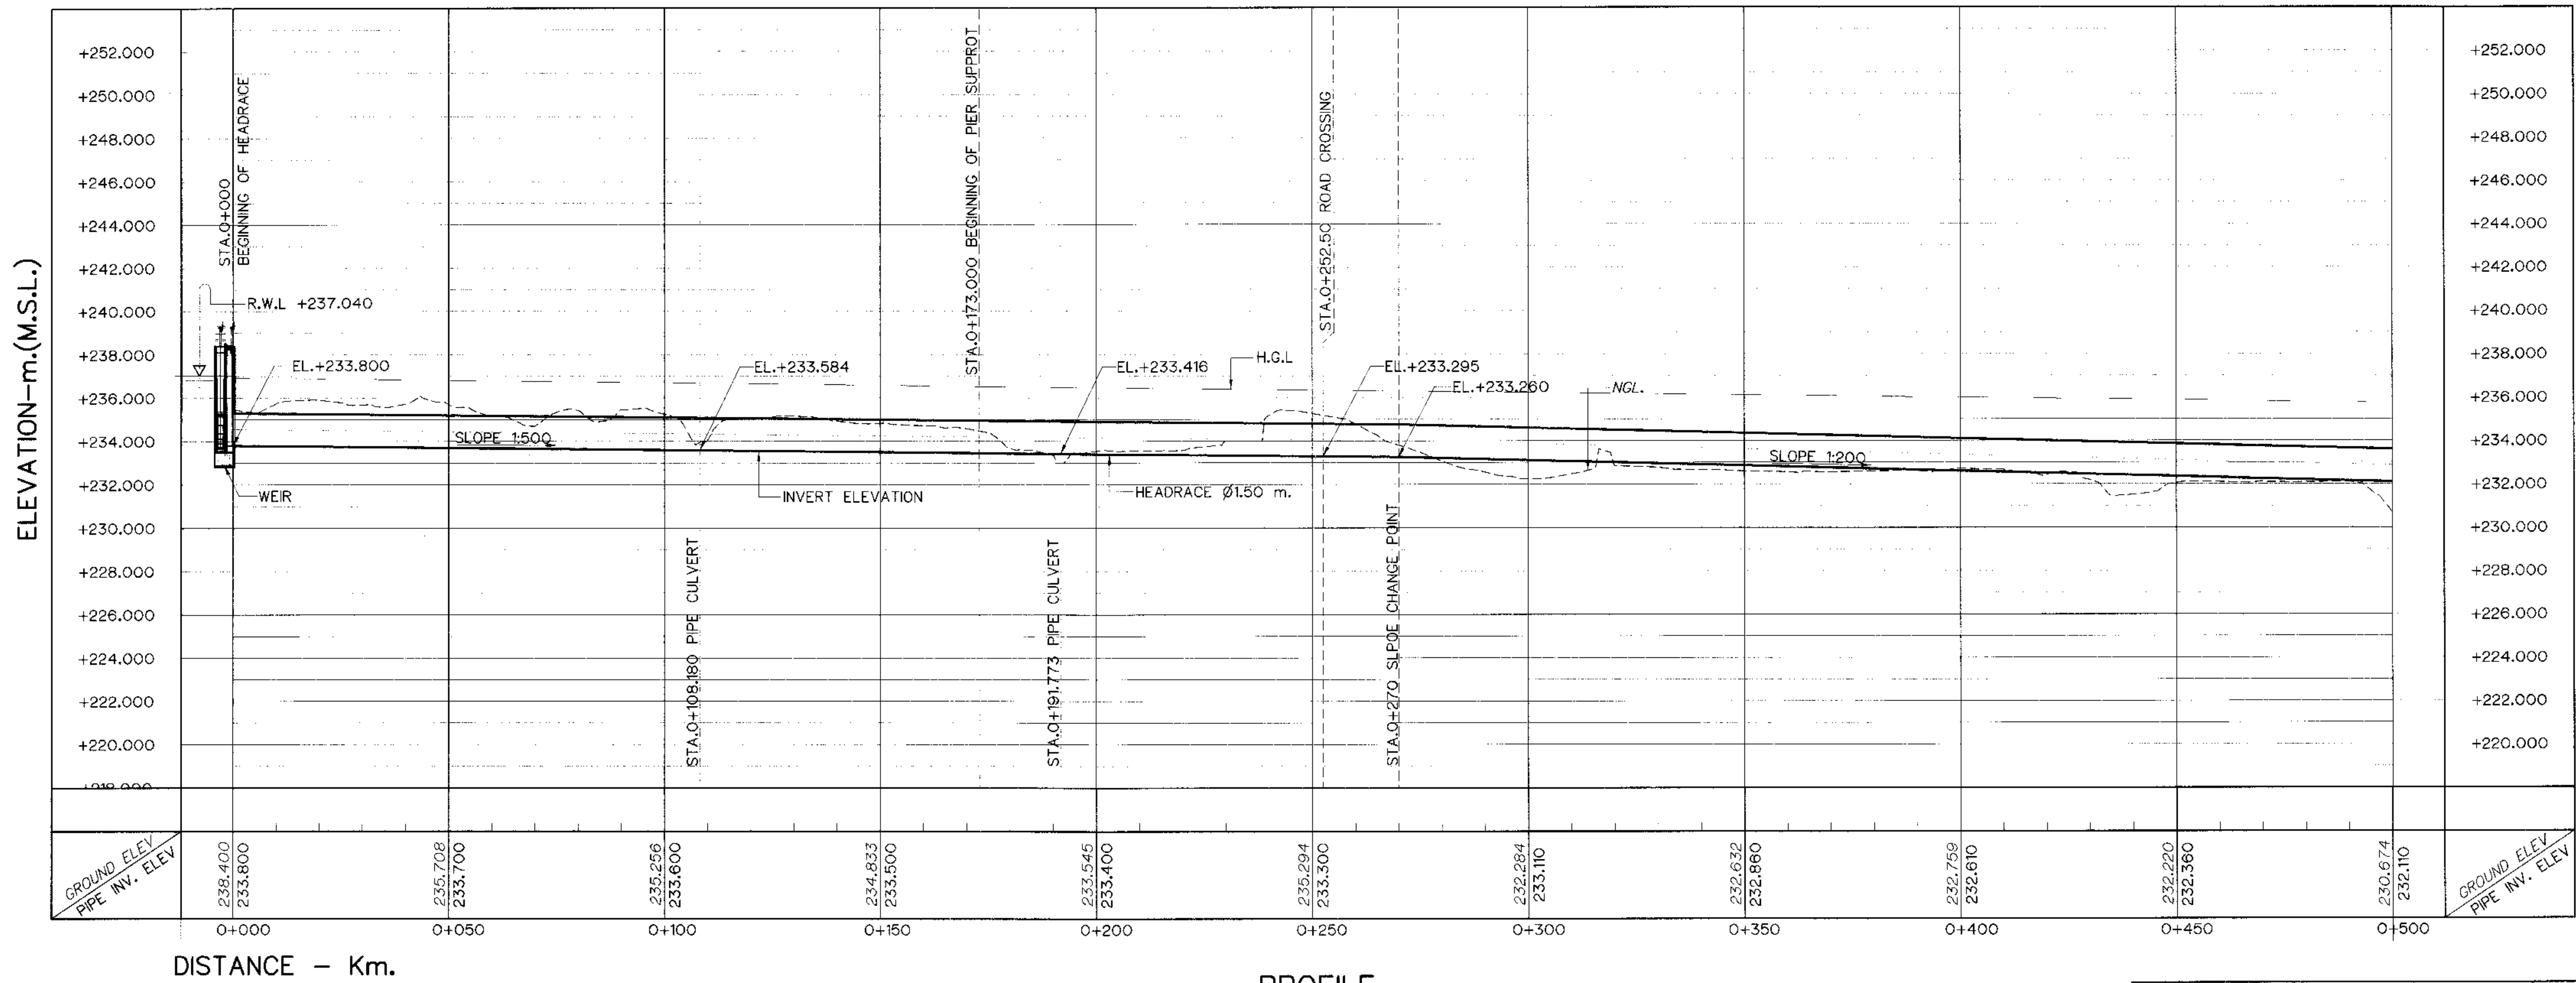

ELEVATION-m.(M.S.L.)

NOTES :

- ALL DIMENSIONS AND ELEVATIONS (M.S.L.) ARE IN METERS. UNLESS OTHERWISE SHOWN.
- SYMBOLS, ABBREVIATIONS AND GENERAL NOTES SEE DWG. NO. KLP-GN-03
- THE ALIGNMENT OF THE HEADRACE AND RELATED STRUCTURES SHALL BE CHECK AND CORRECTED BY THE CONTRACTOR TO SUIT THE FIELD CONDITIONS AND SHALL BE SUBMITTED TO DEDE'S FIELD ENGINEER FOR APPROVAL

REFERENCE DRAWINGS :

- HEADRACE, PLAN AND PROFILE, STA. 0+000 TO STA. 1+000 KLP-HR-04
- HEADRACE, TYPICAL SECTIONS AND DETAILS KLP-HR-06
- HEADRACE, STEEL PIPE AND JOINT DETAILS KLP-HR-07

KINGDOM OF THAILAND Department of Alternative Energy Development and Efficiency MINISTRY OF ENERGY	
KLONG LAM PLOK HYDROPOWER PROJECT	
CIVIL WORKS AND TRANSMISSION LINE HEADRACE PLAN AND PROFILE, STA. 0+000 TO STA. 0+500	
P&C MANAGEMENT CO.,LTD.	REVIEWED
DESIGNED	SUBMITTED
DRAWN	RECOMMENDED
CHECKED	APPROVED
PROJECT MANAGER	DRAWING NO.
DATE	SHEET NO.

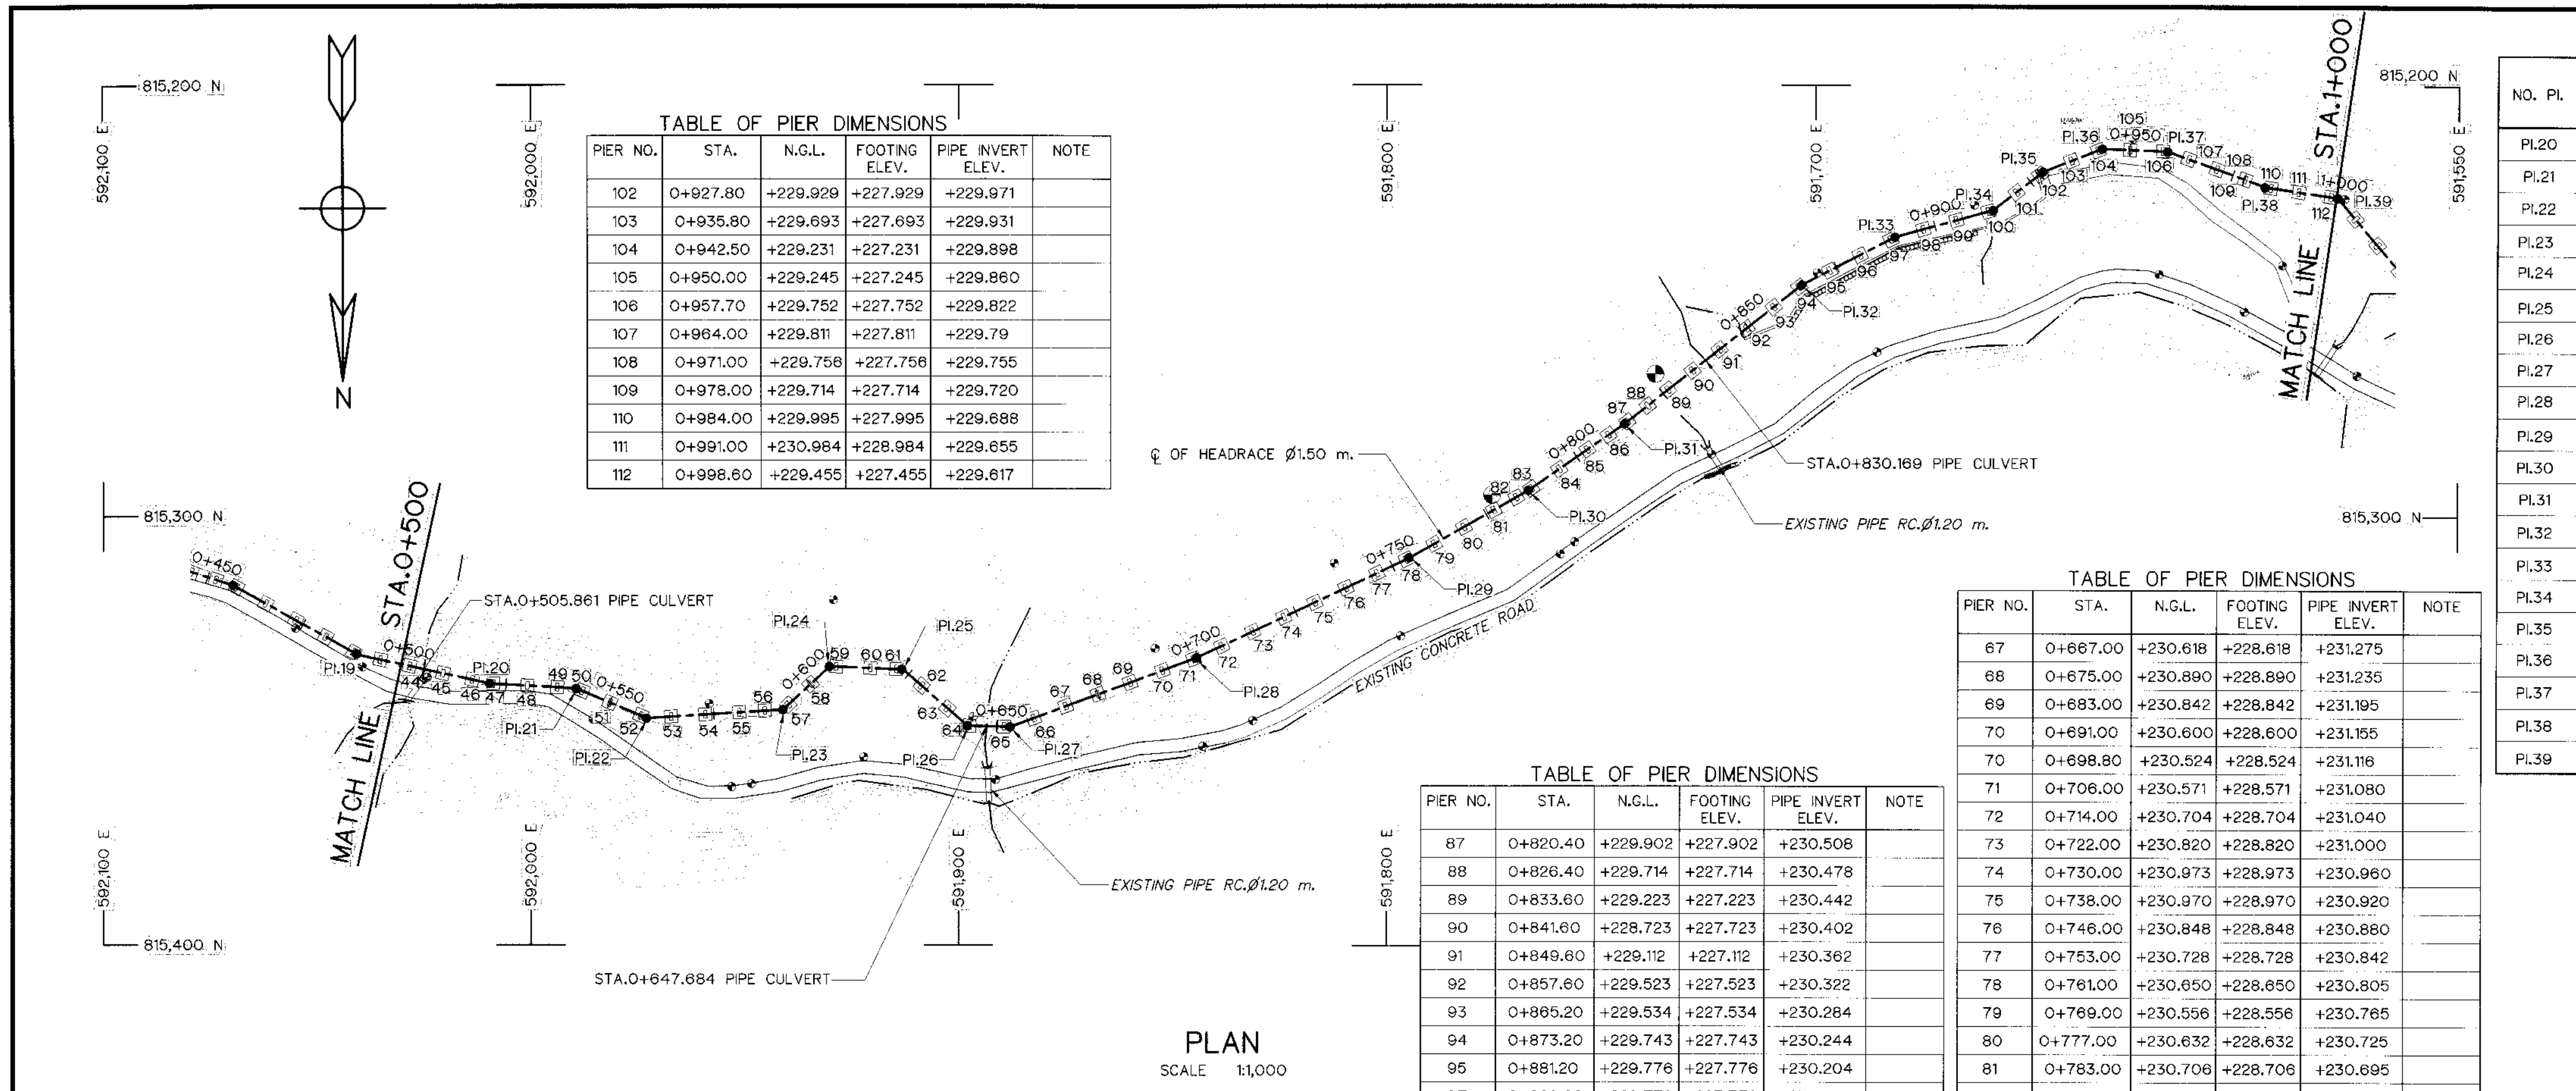



TABLE OF PIER DIMENSIONS				
PIER NO.	STA.	N.G.L.	FOOTING ELEV.	PIPE INVERT ELEV.
102	0+927.80	+229.929	+227.929	+229.971
103	0+935.80	+229.693	+227.693	+229.931
104	0+942.50	+229.231	+227.231	+229.898
105	0+950.00	+229.245	+227.245	+229.860
106	0+957.70	+229.752	+227.752	+229.822
107	0+964.00	+229.811	+227.811	+229.79
108	0+971.00	+229.756	+227.756	+229.755
109	0+978.00	+229.714	+227.714	+229.720
110	0+984.00	+229.995	+227.995	+229.668
111	0+991.00	+230.984	+228.984	+229.655
112	0+998.60	+229.455	+227.455	+229.617

TABLE OF PIER DIMENSIONS				
PIER NO.	STA.	N.G.L.	FOOTING ELEV.	PIPE INVERT ELEV.
87	0+820.40	+229.902	+227.902	+230.508
88	0+826.40	+229.714	+227.714	+230.478
89	0+833.60	+229.223	+227.223	+230.442
90	0+841.60	+228.723	+227.723	+230.402
91	0+849.60	+229.112	+227.112	+230.362
92	0+857.60	+229.523	+227.523	+230.322
93	0+865.20	+229.534	+227.534	+230.284
94	0+873.20	+229.743	+227.743	+230.244
95	0+881.20	+229.776	+227.776	+230.204
97	0+889.20	+229.779	+227.779	+230.164
98	0+897.20	+229.742	+227.742	+230.124
99	0+905.20	+229.680	+227.680	+230.084
100	0+912.90	+229.676	+227.676	+230.046
101	0+920.90	+229.728	+227.728	+230.006

TABLE OF PIER DIMENSIONS				
PIER NO.	STA.	N.G.L.	FOOTING ELEV.	PIPE INVERT ELEV.
67	0+667.00	+230.618	+228.618	+231.275
68	0+675.00	+230.890	+228.890	+231.235
69	0+683.00	+230.842	+228.842	+231.195
70	0+691.00	+230.600	+228.600	+231.155
70	0+698.80	+230.524	+228.524	+231.116
71	0+706.00	+230.571	+228.571	+231.080
72	0+714.00	+230.704	+228.704	+231.040
73	0+722.00	+230.820	+228.820	+231.000
74	0+730.00	+230.973	+228.973	+230.960
75	0+738.00	+230.970	+228.970	+230.920
76	0+746.00	+230.848	+228.848	+230.880
77	0+753.00	+230.728	+228.728	+230.842
78	0+761.00	+230.650	+228.650	+230.805
79	0+769.00	+230.556	+228.556	+230.765
80	0+777.00	+230.632	+228.632	+230.725
81	0+783.00	+230.706	+228.706	+230.695
82	0+787.10	+230.638	+228.638	+230.675
83	0+795.00	+230.370	+228.370	+230.635
84	0+803.00	+229.980	+227.980	+230.595
85	0+809.00	+229.971	+227.971	+230.565
86	0+814.40	+229.967	+227.967	+230.538

HORIZONTAL CURVE OF HEADRACE					
NO. PI.	COORDINATE OF PI.		PL. TO PL. (m)	DEFLECTION ANGLE (°)	PI. STA.
	N	E			
PI.20	815,338.979	592,009.633	31.545	08°-53'-13.29"	0+521.220
PI.21	815,340.135	591,989.455	20.211	19°-24'-02.34"	0+541.431
PI.22	815,347.054	591,972.898	17.945	26°-15'-54.64"	0+559.376
PI.23	815,345.058	591,941.045	31.915	39°-04'-59.92"	0+591.291
PI.24	815,335.019	591,930.154	14.812	45°-05'-37.90"	0+606.103
PI.25	815,335.744	591,913.034	17.135	38°-25'-37.37"	0+623.238
PI.26	815,348.782	591,897.957	19.933	39°-27'-30.77"	0+643.171
PI.27	815,349.026	591,887.926	10.034	21°-36'-25.83"	0+653.205
PI.28	815,333.003	591,844.409	46.373	04°-50'-25.86"	0+699.578
PI.29	815,309.831	591,794.839	54.719	04°-25'-49.44"	0+754.297
PI.30	815,294.053	591,766.934	32.057	05°-07'-19.80"	0+786.354
PI.31	815,278.586	591,744.490	27.269	03°-20'-11.23"	0+813.623
PI.32	815,246.378	591,703.207	52.348	10°-47'-46.25"	0+865.971
PI.33	815,235.249	591,681.503	24.391	11°-45'-40.86"	0+890.362
PI.34	815,228.970	591,658.685	23.666	21°-49'-30.63"	0+914.028
PI.35	815,219.987	591,646.855	14.854	15°-59'-40.34"	0+928.882
PI.36	815,214.676	591,633.174	14.676	23°-21'-45.41"	0+943.558
PI.37	815,215.247	591,617.938	15.247	17°-37'-16.47"	0+958.805
PI.38	815,223.502	591,594.968	24.408	11°-26'-35.69"	0+983.213
PI.39	815,225.961	591,578.162	16.985	41°-29'-11.54"	1+000.198

TABLE OF PIER DIMENSIONS				
PIER NO.	STA.	N.G.L.	FOOTING ELEV.	PIPE INVERT ELEV.
44	0+502.00	+230.653	+228.653	+232.100
45	0+510.50	+230.846	+228.846	+232.060
46	0+517.50	+230.806	+228.806	+232.025
47	0+522.00	+231.034	+229.034	+232.000
48	0+530.00	+231.337	+229.337	+231.960
49	0+537.00	+231.261	+229.261	+231.925
50	0+543.50	+230.737	+228.737	+231.895
51	0+550.00	+230.305	+228.305	+231.860
52	0+557.80	+229.952	+227.952	+231.821
53	0+565.00	+229.678	+227.678	+231.785
54	0+573.00	+229.678	+227.678	+231.745
55	0+581.00	+229.445	+227.445	+231.705
56	0+587.00	+229.642	+227.642	+231.675
57	0+592.00	+230.000	+228.000	+231.646
58	0+600.00	+230.996	+228.996	+231.610
59	0+607.600	+230.587	+228.587	+231.572
60	0+615.600	+230.000	+228.000	+231.532
61	0+621.700	+230.000	+228.000	+231.502
62	0+629.000	+230.370	+228.370	+231.465
63	0+637.000	+229.785	+227.785	+231.425
64	0+643.700	+230.679	+228.679	+231.392
65	0+651.000	+230.954	+228.954	+231.352
66	0+659.00	+230.618	+228.618	+231.315

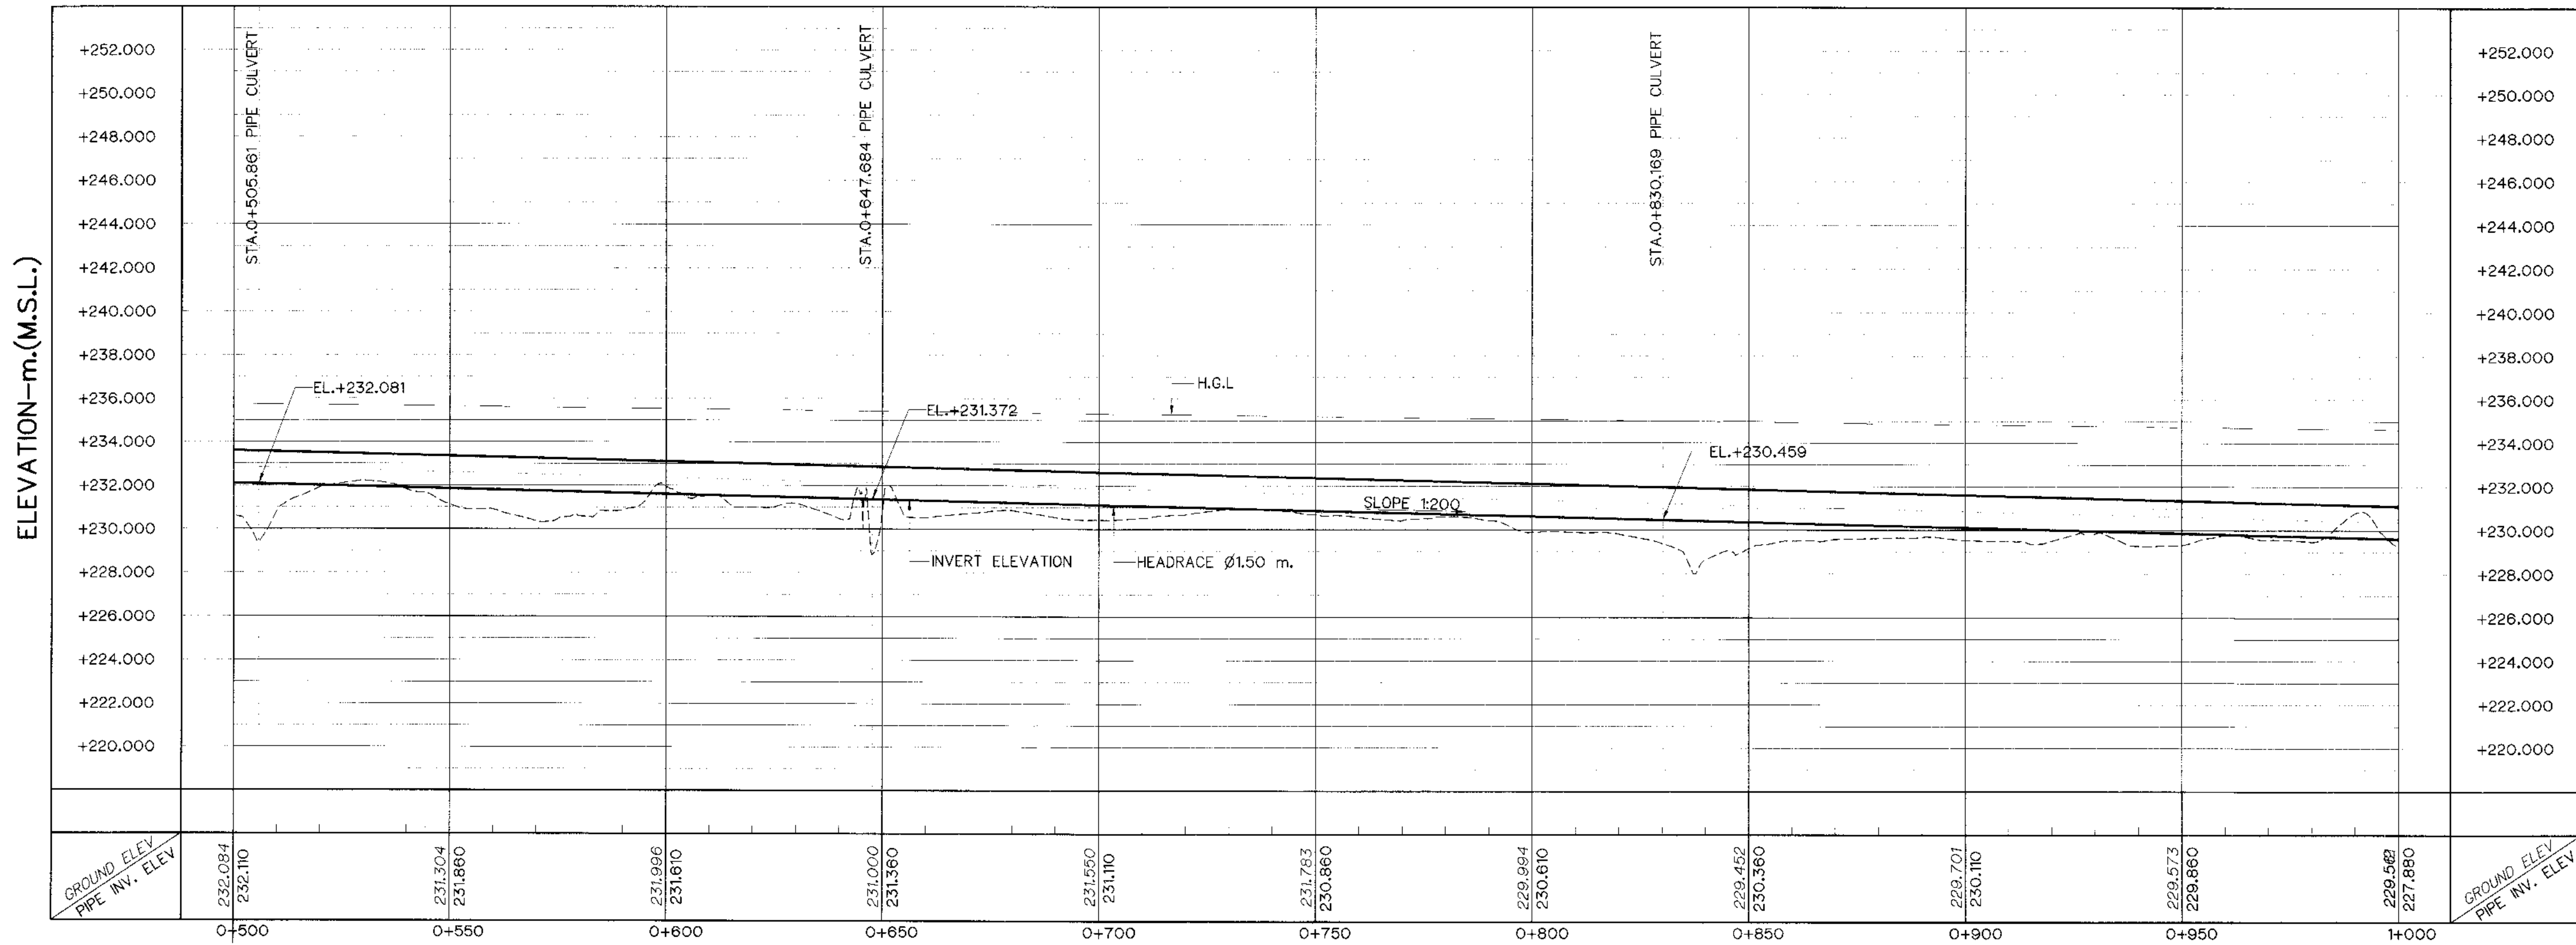

- NOTES :
- ALL DIMENSIONS AND ELEVATIONS (M.S.L.) ARE IN METERS. UNLESS OTHERWISE SHOWN.
 - SYMBOLS, ABBREVIATIONS AND GENERAL NOTES SEE DWG. NO. KLP-GN-03
 - THE ALIGNMENT OF THE HEADRACE AND RELATED STRUCTURES SHALL BE CHECK AND CORRECTED BY THE CONTRACTOR TO SUIT THE FIELD CONDITIONS AND SHALL BE SUBMITTED TO DEDE'S FIELD ENGINEER FOR APPROVAL
- REFERENCE DRAWINGS :
- HEADRACE, PLAN AND PROFILE, STA. 0+000 TO STA. 0+500 KLP-HR-03
 - HEADRACE, PLAN AND PROFILE, STA. 1+000 TO STA. 1+459.508 KLP-HR-05
 - HEADRACE, TYPICAL SECTIONS AND DETAILS KLP-HR-06
 - HEADRACE, STEEL PIPE AND JOINT DETAILS KLP-HR-07

KINGDOM OF THAILAND
Department of Alternative
Energy Development and Efficiency
MINISTRY OF ENERGY

KLONG LAM PLOK HYDROPOWER PROJECT

CIVIL WORKS AND TRANSMISSION LINE
HEADRACE
PLAN AND PROFILE, STA. 0+500 TO STA. 1+000

P&C MANAGEMENT CO., LTD.

KINGDOM OF THAILAND
Department of Alternative
Energy Development and Efficiency
MINISTRY OF ENERGY

DESIGNED 08/29074 08/2226

DRAWN

CHECKED 08/2226

PROJECT MANAGER

REVIEWED

SUBMITTED


RECOMMENDED

APPROVED

DRAWING NO. KLP-HR-04


SHEET NO. 27 OF 110

PROFILE
VERTICAL SCALE 1:200
HORIZONTAL SCALE 1:1,000

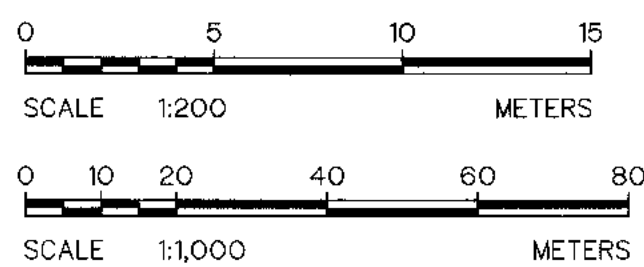

NO.	DATE	REVISIONS	CHECKED	APPROVED
3				
2				
1				

CONSULTANTS	DEDE

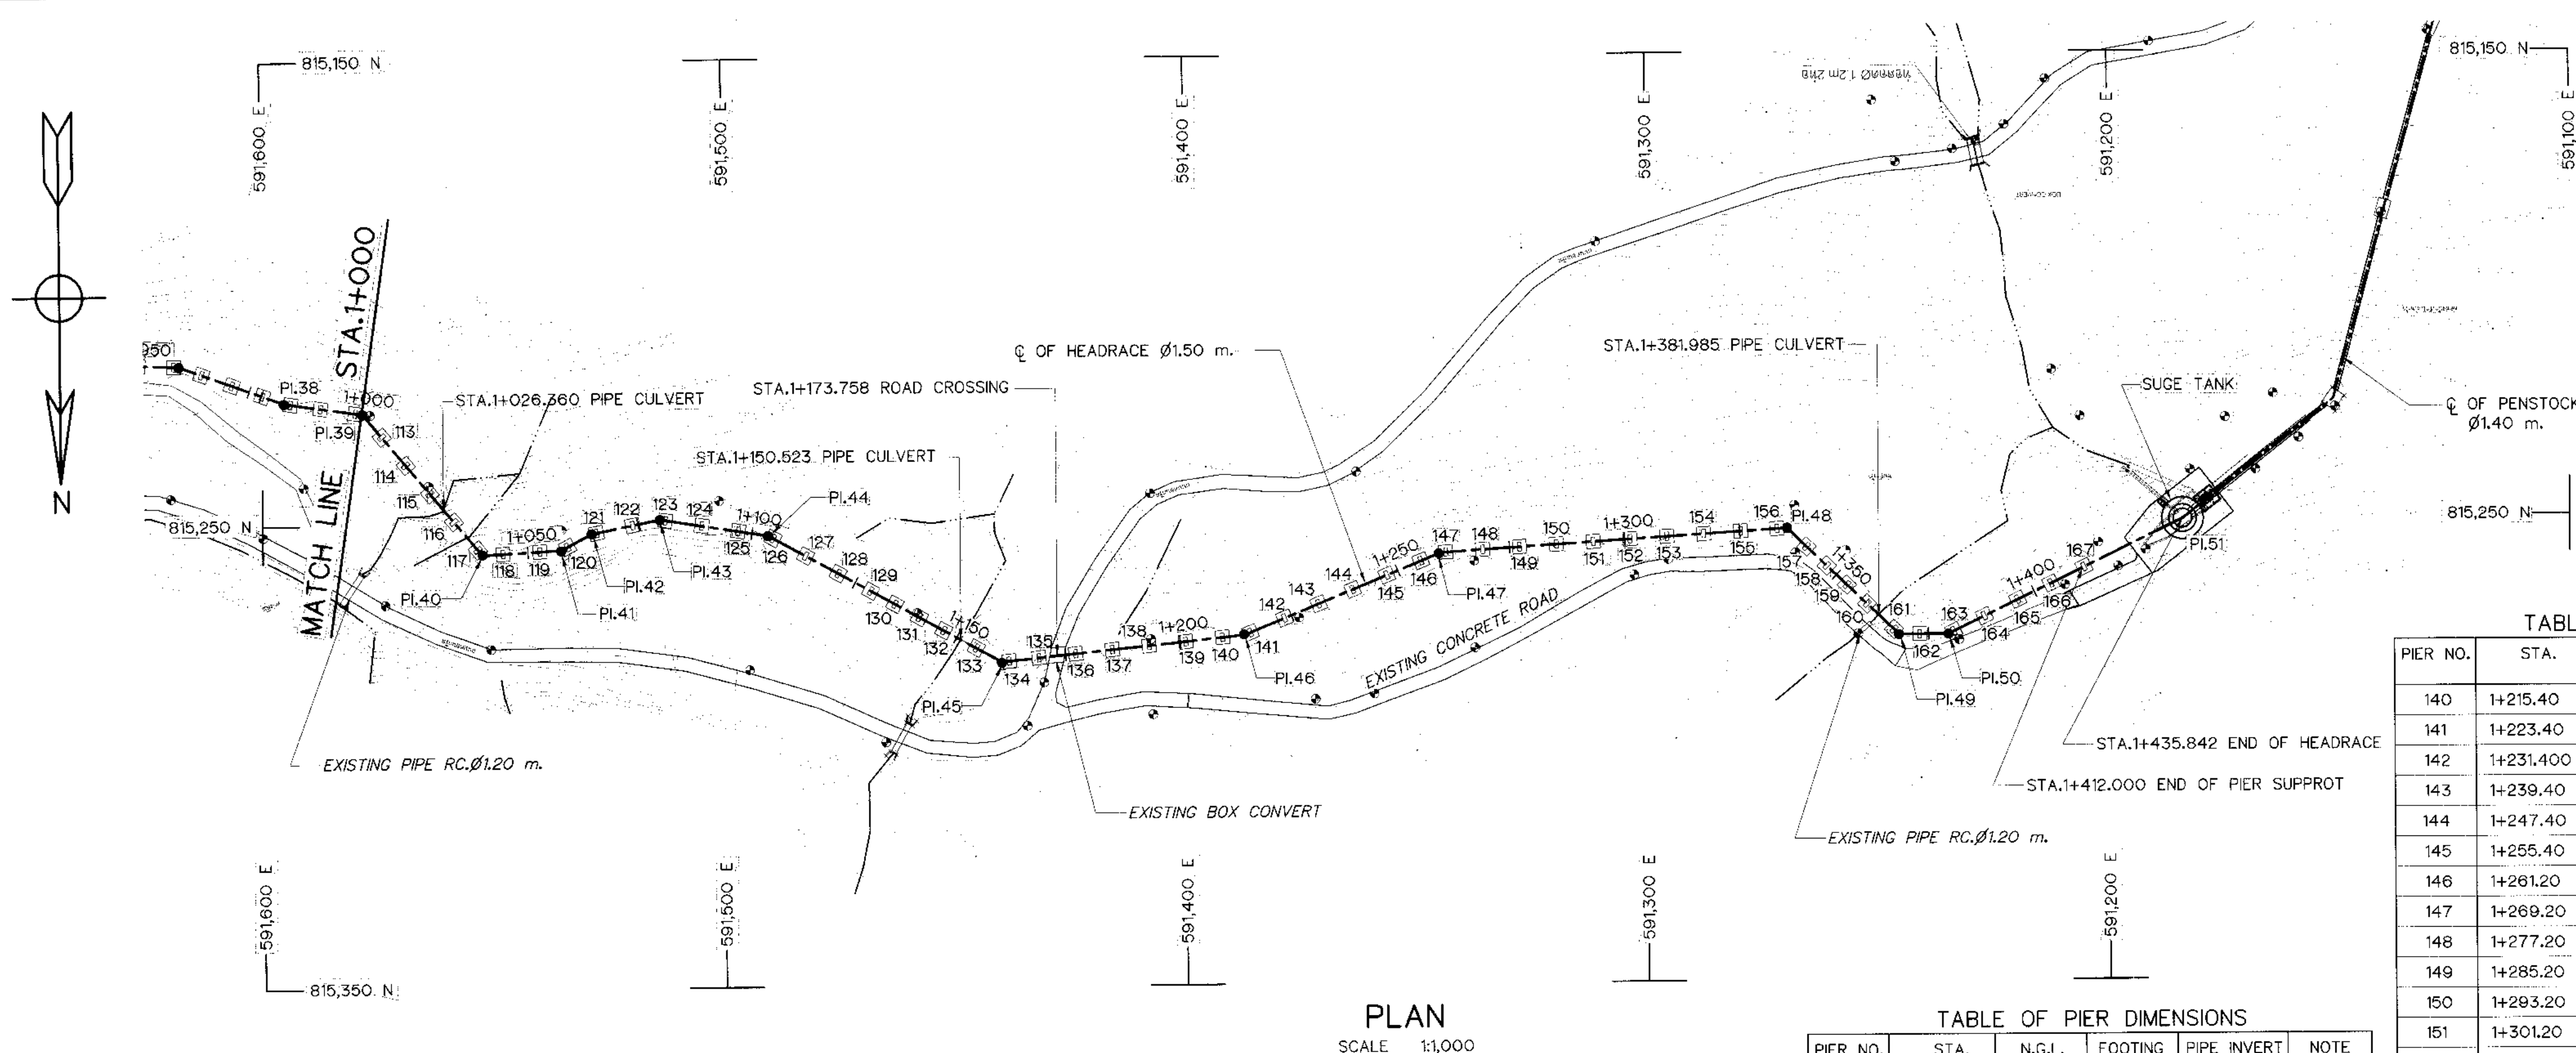

PLAN
SCALE 1:1,000

HORIZONTAL CURVE OF HEADRACE

NO. PI.	COORDINATE OF PI.		PL TO PL (m)	DEFLECTION ANGLE (Δ) (° - ' - ")	PL STA. (km)	BEARING (N/S - ° - ' - " E/W)
	N	E				
PI.39	815,225.961	591,578.182	16.985	41° - 29' - 11.54"	1+000.198	N 81° - 40' - 32.84" W
PI.40	815,256.478	591,552.383	39.948	53° - 06' - 09.84"	1+040.146	N 40° - 11' - 21.10" W
PI.41	815,255.493	591,535.258	17.153	24° - 13' - 04.07"	1+057.299	S 86° - 42' - 29.07" W
PI.42	815,252.06	591,528.866	7.432	15° - 59' - 52.41"	1+064.731	S 62° - 29' - 25.00" W
PI.43	815,249.05	591,513.887	15.082	20° - 20' - 28.80"	1+079.813	S 78° - 29' - 17.40" W
PI.44	815,252.703	591,490.37	23.799	19° - 46' - 55.37"	1+103.612	N 81° - 10' - 14.00" W
PI.45	815,280.266	591,439.84	57.559	34° - 39' - 57.81"	1+181.171	N 61° - 23' - 18.63" W
PI.46	815,274.67	591,387.081	53.055	16° - 20' - 35.47"	1+214.226	S 83° - 56' - 43.56" W
PI.47	815,257.212	591,344.72	45.817	18° - 46' - 28.36"	1+260.043	S 67° - 36' - 08.09" W
PI.48	815,252.461	591,269.69	75.180	47° - 07' - 06.65"	1+335.223	S 86° - 22' - 36.45" W
PI.49	815,275.481	591,245.428	33.445	44° - 01' - 05.86"	1+368.668	N 46° - 30' - 16.90" W
PI.50	815,275.383	591,234.692	10.736	25° - 21' - 26.64"	1+379.404	S 89° - 28' - 37.23" W
PI.51	815,250.748	591,183.914	56.438			

TABLE OF PIER DIMENSIONS


PIER NO.	STA.	N.G.L.	FOOTING ELEV.	PIPE INVERT ELEV.	NOTE
140	1+215.40	+227.398	+225.398	+228.533	
141	1+223.40	+226.845	+224.845	+228.493	
142	1+231.400	+225.721	+223.721	+228.453	
143	1+239.40	+225.487	+223.487	+228.413	
144	1+247.40	+227.733	+225.733	+228.373	
145	1+255.40	+228.689	+226.689	+228.333	
146	1+261.20	+228.701	+226.701	+228.304	
147	1+269.20	+229.312	+227.312	+228.264	
148	1+277.20	+228.887	+226.887	+228.224	
149	1+285.20	+227.901	+225.901	+228.184	
150	1+293.20	+226.988	+224.988	+228.144	
151	1+301.20	+226.811	+224.811	+228.104	
152	1+309.20	+226.975	+224.975	+228.064	
153	1+317.20	+227.257	+225.257	+228.024	
154	1+325.20	+227.901	+225.901	+227.984	
155	1+333.10	+227.325	+225.325	+227.945	
156	1+341.10	+227.000	+225.000	+227.905	
157	1+347.10	+226.235	+224.235	+228.064	
158	1+353.10	+225.301	+224.301	+228.024	
159	1+359.10	+223.369	+221.369	+228.024	

TABLE OF PIER DIMENSIONS


PIER NO.	STA.	N.G.L.	FOOTING ELEV.	PIPE INVERT ELEV.	NOTE
160	1+367.10	+225.000	+223.000	+227.775	
161	1+373.10	+225.922	+223.922	+227.745	
162	1+380.60	+226.831	+224.831	+227.707	
163	1+388.00	+226.655	+224.655	+227.670	
164	1+396.00	+226.846	+224.846	+227.630	
165	1+404.00	+227.112	+225.112	+227.590	
167	1+412.00	+227.550	+225.550	+227.550	

TABLE OF PIER DIMENSIONS

PIER NO.	STA.	N.G.L.	FOOTING ELEV.	PIPE INVERT ELEV.	NOTE
113	1+006.80	+229.000	+227.000	+229.577	
114	1+014.60	+229.432	+227.432	+229.537	
115	1+022.60	+228.711	+226.711	+229.497	
116	1+030.60	+228.402	+226.402	+229.457	
117	1+038.60	+228.722	+226.722	+229.417	
118	1+044.60	+228.215	+226.215	+229.387	
119	1+052.60	+228.312	+226.312	+229.347	
120	1+058.80	+228.634	+226.634	+229.316	
121	1+065.80	+228.504	+226.504	+229.281	
122	1+073.80	+228.753	+226.753	+229.241	
123	1+081.80	+228.695	+226.695	+229.205	
124	1+089.00	+228.825	+226.825	+229.165	
125	1+104.80	+228.802	+226.802	+229.086	
126	1+112.80	+228.695	+226.695	+229.046	
127	1+120.80	+228.478	+226.478	+229.006	
128	1+128.80	+228.678	+226.678	+228.966	
129	1+134.80	+228.673	+226.673	+228.936	
130	1+140.80	+227.367	+225.367	+228.906	
131	1+146.80	+226.675	+224.675	+228.876	
132	1+154.80	+226.698	+224.698	+228.836	
133	1+162.70	+227.745	+225.745	+228.797	
134	1+169.20	+228.326	+226.326	+228.764	
135	1+177.20	+229.678	+227.678	+228.724	
136	1+185.20	+228.779	+226.779	+228.684	
137	1+193.20	+227.765	+225.765	+228.644	
138	1+201.20	+227.324	+225.324	+228.604	
139	1+209.20	+227.325	+225.325	+228.564	

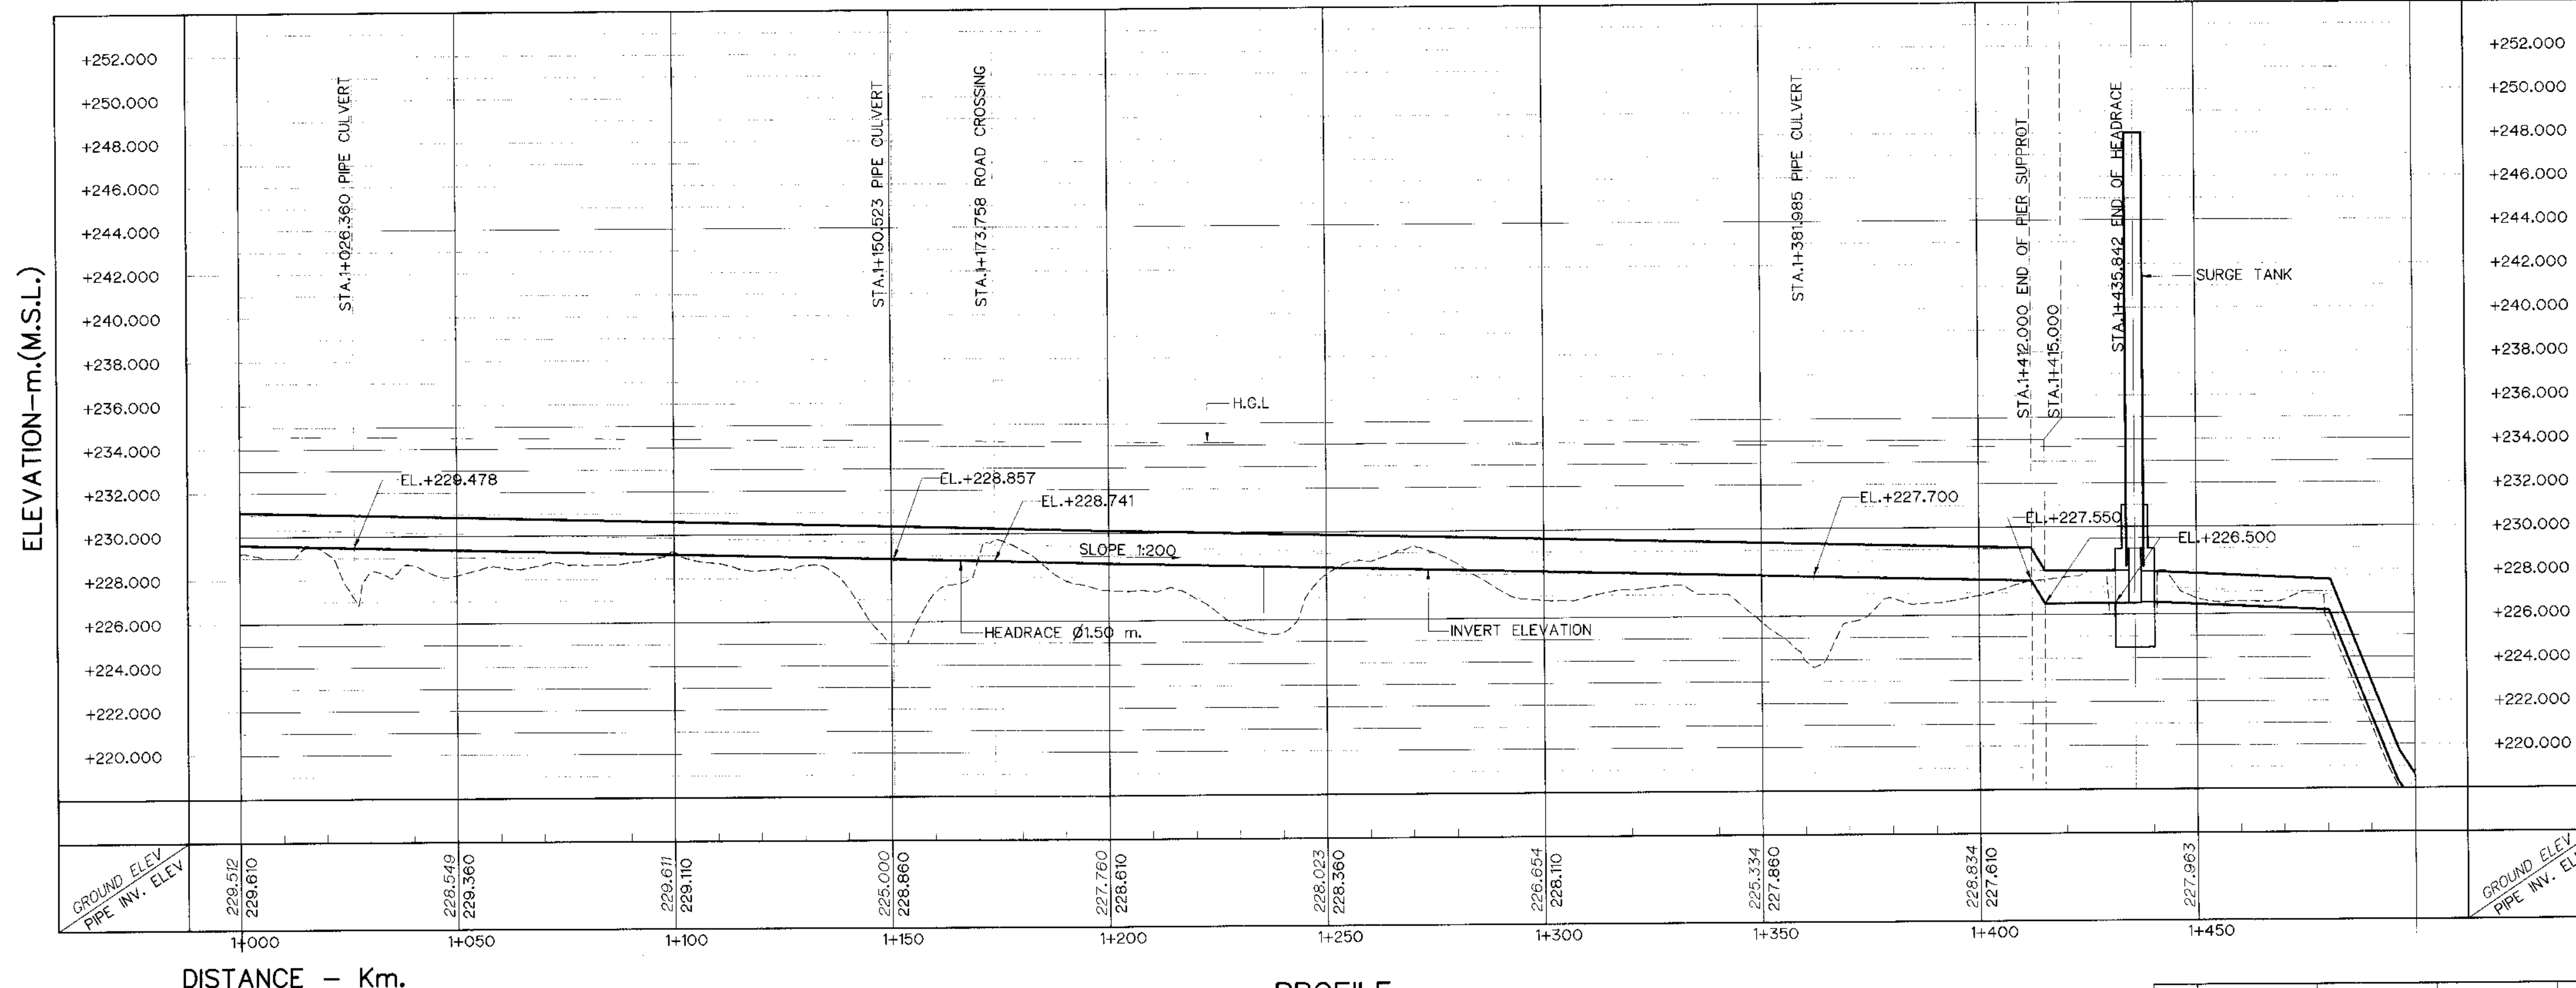

PROFILE
VERTICAL SCALE 1:200
HORIZONTAL SCALE 1:1,000

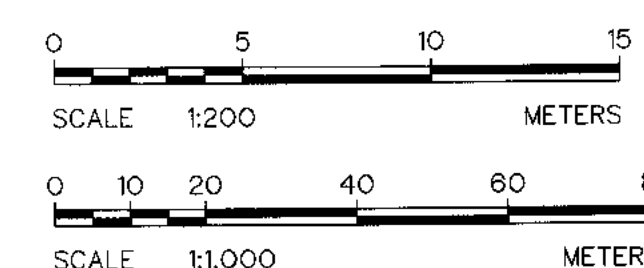


- NOTES :
- ALL DIMENSIONS AND ELEVATIONS (M.S.L.) ARE IN METERS, UNLESS OTHERWISE SHOWN.
 - SYMBOLS, ABBREVIATIONS AND GENERAL NOTES SEE DWG. NO. KLP-GN-03
 - THE ALIGNMENT OF THE HEADRACE AND RELATED STRUCTURES SHALL BE CHECK AND CORRECTED BY THE CONTRACTOR TO SUIT THE FIELD CONDITIONS AND SHALL BE SUBMITTED TO DEDE'S FIELD ENGINEER FOR APPROVAL


REFERENCE DRAWINGS :

- HEADRACE, PLAN AND PROFILE, STA. 1+000 TO STA. 1+500 KLP-HR-04
- HEADRACE, TYPICAL SECTIONS AND DETAILS KLP-HR-06
- HEADRACE, STEEL PIPE AND JOINT DETAILS KLP-HR-07

KINGDOM OF THAILAND Department of Alternative Energy Development and Efficiency MINISTRY OF ENERGY	
KLONG LAM PLOK HYDROPOWER PROJECT	
CIVIL WORKS AND TRANSMISSION LINE HEADRACE PLAN AND PROFILE, STA. 1+000 TO STA. 1+459.506	
DESIGNED <i>[Signature]</i> 01/29/04 DRAWN <i>[Signature]</i> CHECKED <i>[Signature]</i> 01/29/04 PROJECT MANAGER	SUBMITTED <i>[Signature]</i> RECOMMENDED <i>[Signature]</i> APPROVED <i>[Signature]</i> 01/29/04 DATE
NO. DATE REVISIONS CHECKED APPROVED CONSULTANTS DEDE	DRAWING NO. KLP-HR-05 SHEET NO. 28 OF 110

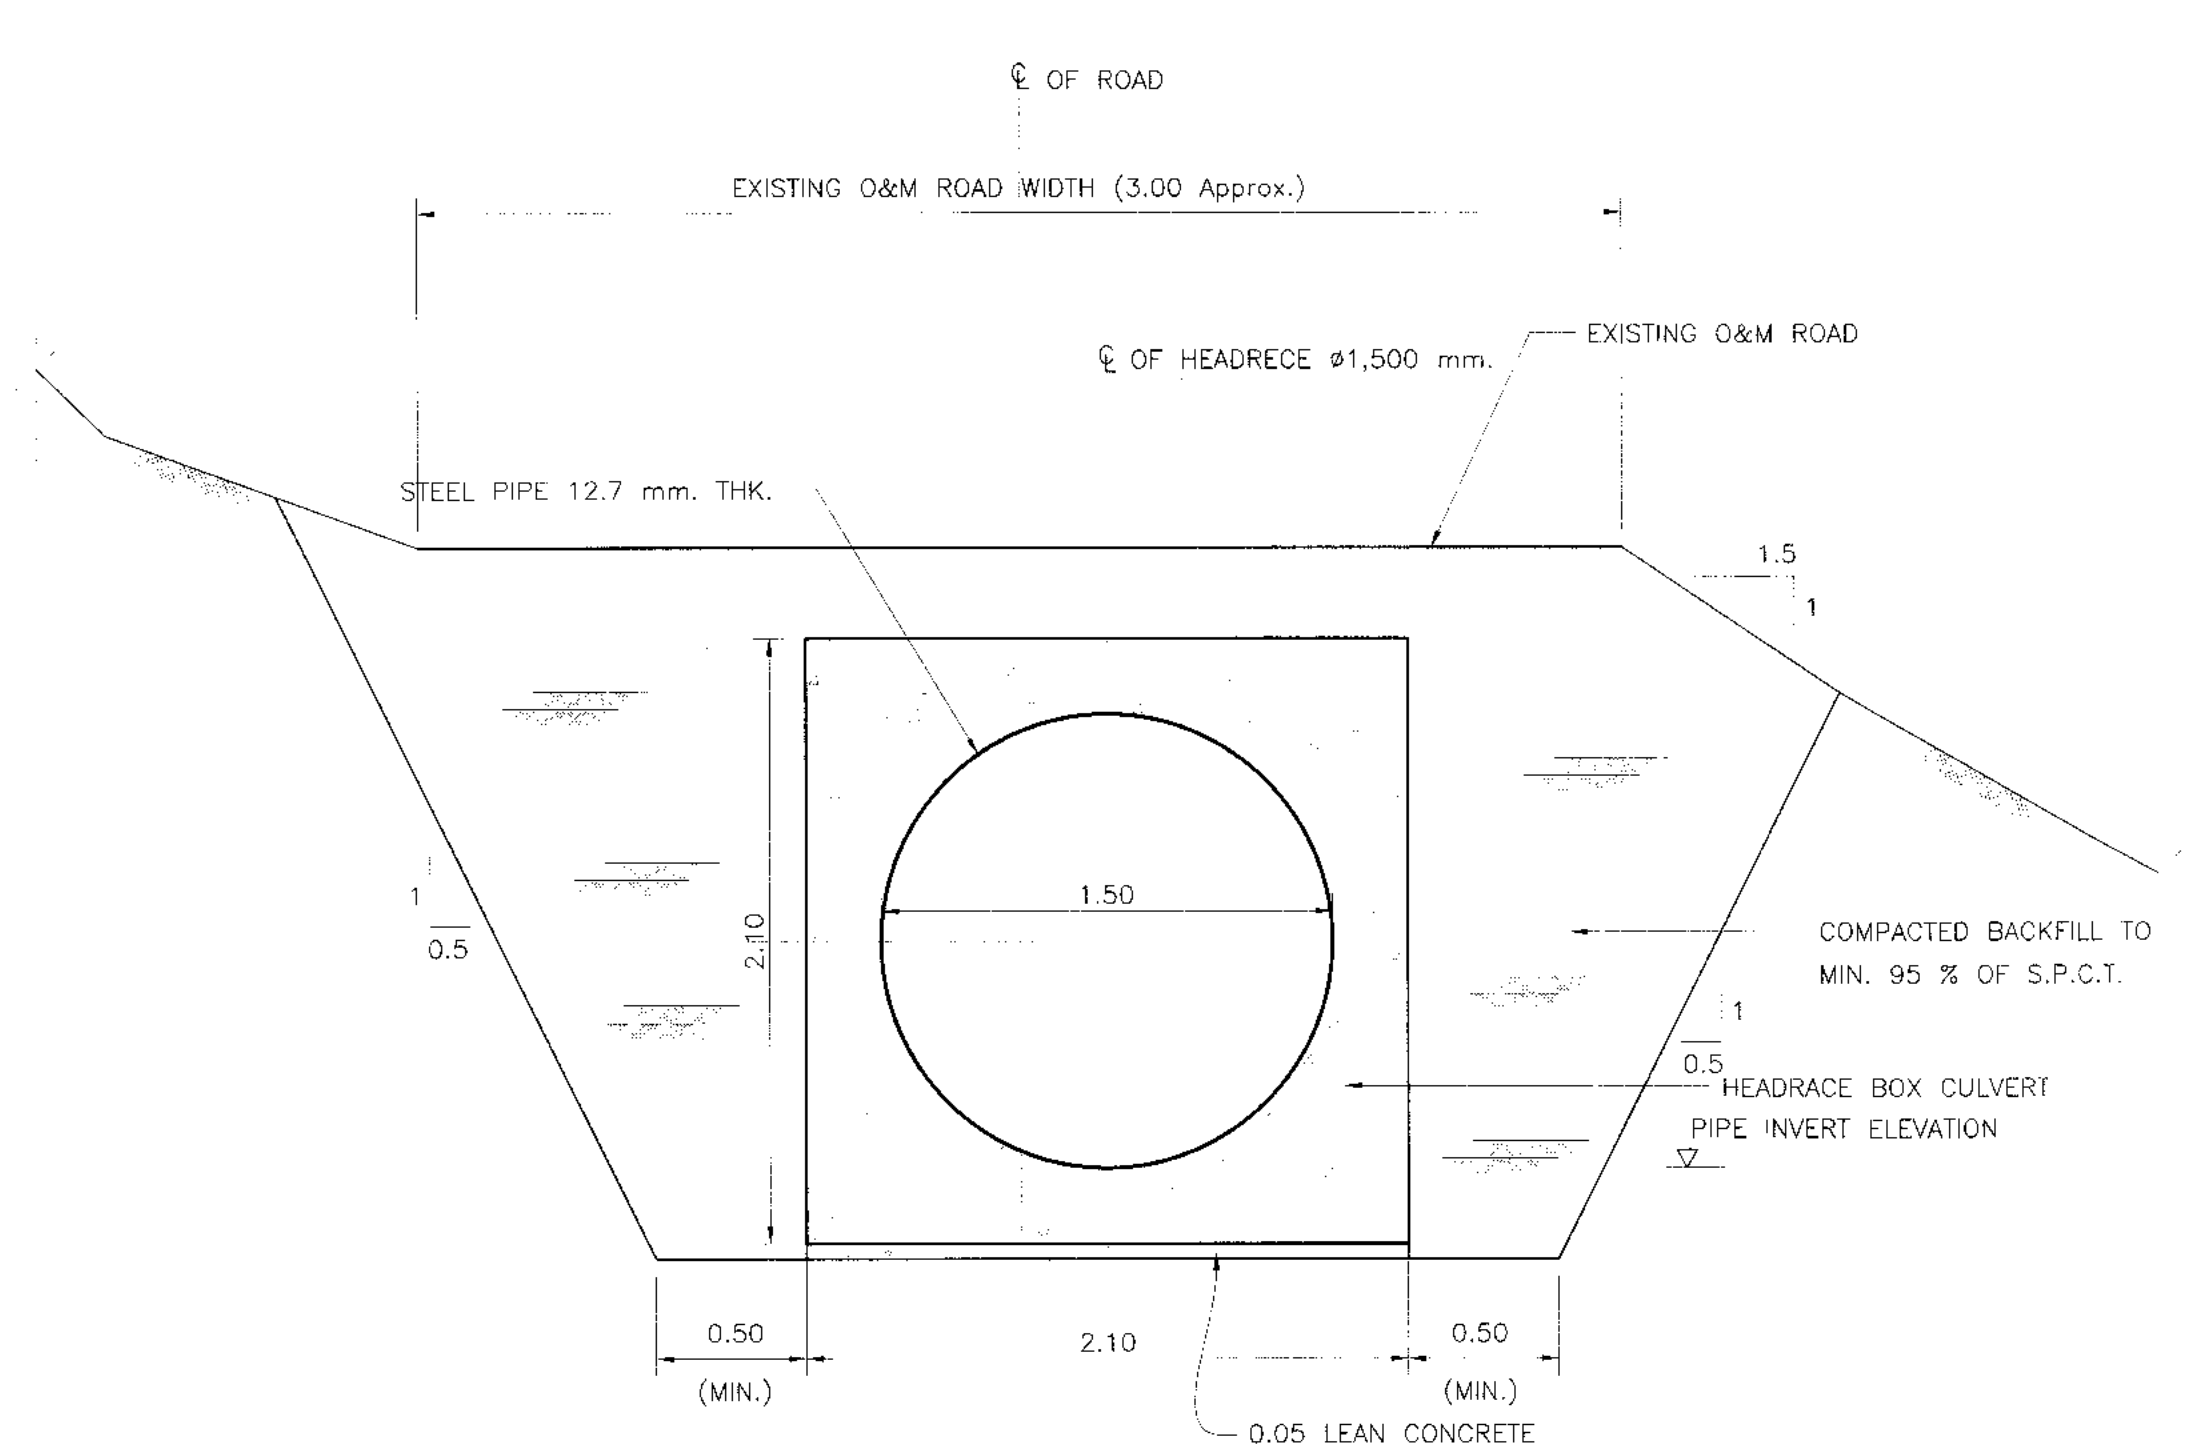


EARTH EXCAVATION
NOT TO SCALE

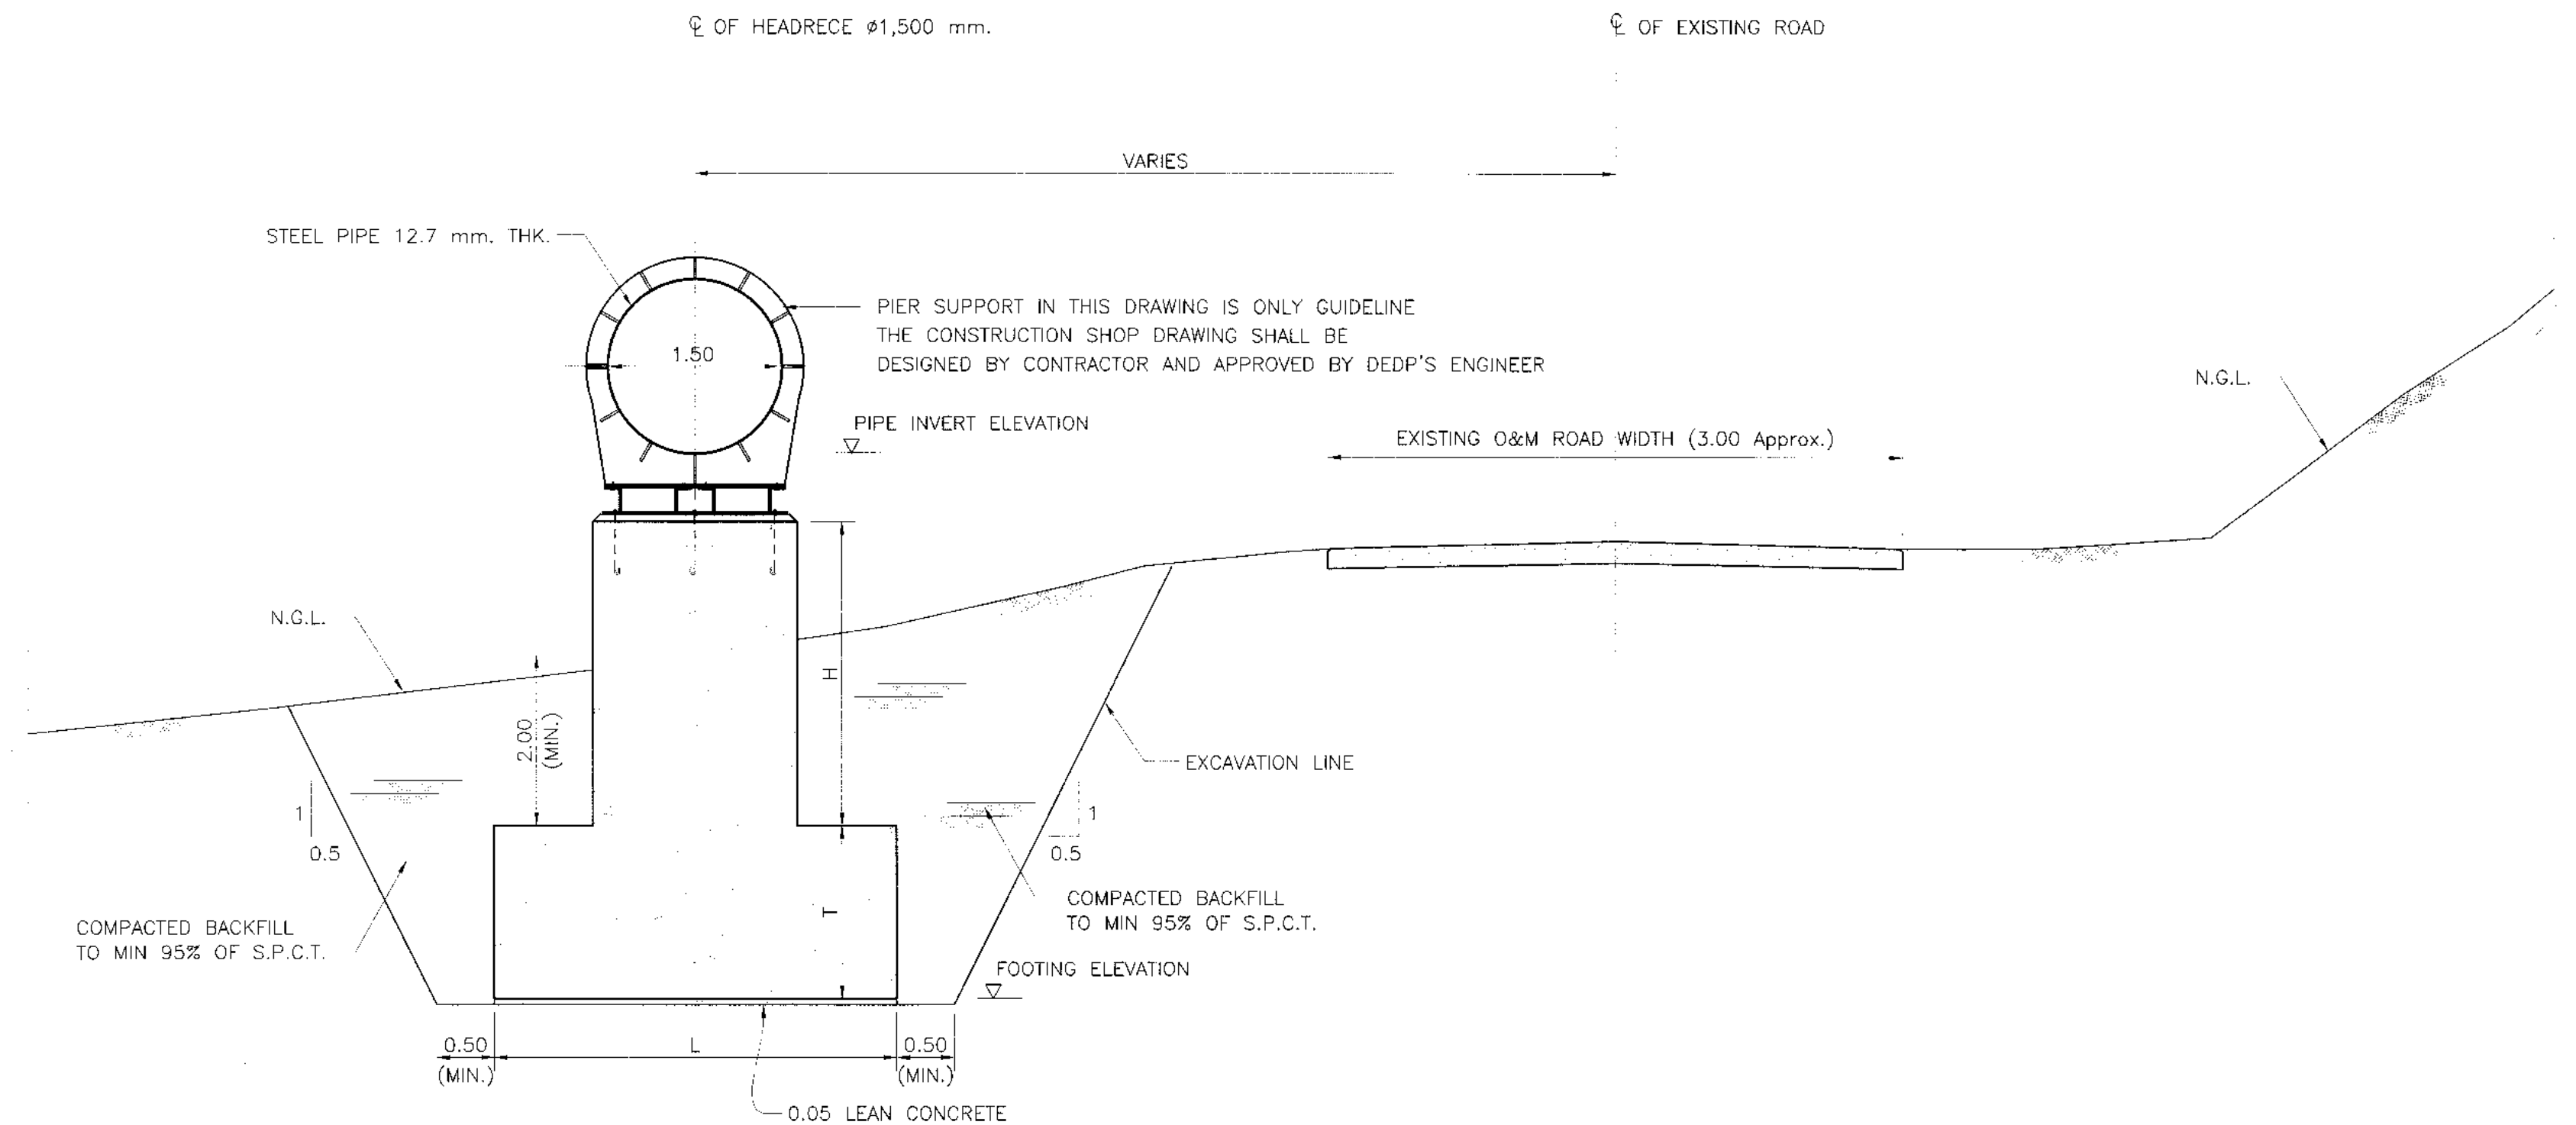

CONCRETE PIER
SCALE 1:50

TYPICAL SECTIONS OF HEADRACE
SCALE 1:50

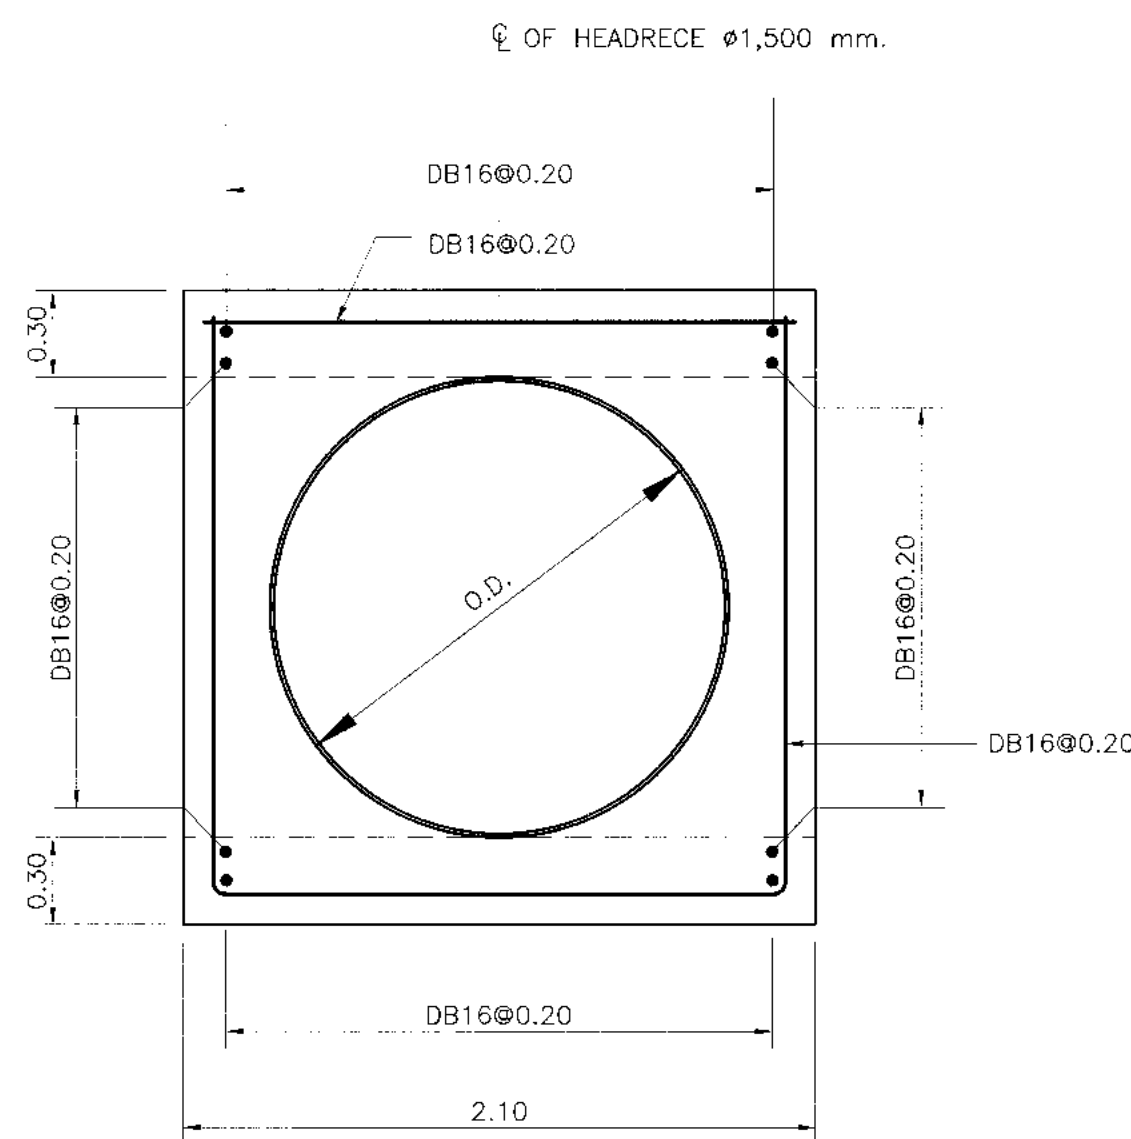

HEADRACE BOX CONCRETE
REINFORCEMENT DETAIL
NOT TO SCALE

TABLE OF HEADRACE SUPPORT


STA TO STA	TYPE OF HEADRACE SUPPORT
0+000 - 0+173	EARTH EXCAVATION
0+173 - 1+412	PIER
1+412 - 1+435.842	EARTH EXCAVATION

NOTES :


- ALL DIMENSIONS AND ELEVATIONS (M.S.L.) ARE IN METERS, UNLESS OTHERWISE SHOWN.
- SYMBOLS, ABBREVIATIONS AND GENERAL NOTES SEE DWG. NO. KLP-GN-03
- CONCRETE DESIGN BASED ON THE COMPRESSIVE STRENGTH OF 210 KSC, STANDARD CYLINDER $\phi 0.15 \times 0.30$ m. TEST AT AGE 28 DAYS, UNLESS OTHERWISE INDICATED IN SPECIFIC DRAWINGS.
- ULTIMATE TENSILE STRESSES OF REINFORCING STEEL, CONFORM TO THE REQUIREMENT OF THAI INDUSTRIAL STANDARD DESIGNATION SR24 FOR STRUCTURAL GRADE PLAIN ROUND BAR AND SD30 FOR INTERMEDIATE GRADE DEFORMED BAR.

REFERENCE DRAWINGS :

 
- HEADRACE, CONCRETE PIER SECTION AND DETAIL KLP-HR-08




KINGDOM OF THAILAND Department of Alternative Energy Development and Efficiency MINISTRY OF ENERGY	
KLONG LAM PLOK HYDROPOWER PROJECT	
CIVIL WORKS AND TRANSMISSION LINE HEADRACE TYPICAL SECTIONS AND DETAILS	
P&C MANAGEMENT CO.,LTD. DESIGNED: 08/29/07 DRAWN: 08/22/08 NO. DATE REVISIONS CHECKED APPROVED CONSULTANTS DEDE	Department of Alternative Energy Development and Efficiency MINISTRY OF ENERGY REVIEWED: 08/22/08 SUBMITTED: 08/22/08 RECOMMENDED: 08/22/08 APPROVED: 08/22/08 PROJECT MANAGER DATE
DRAWING NO. KLP-HR-06	SHEET NO. 29 OF 110

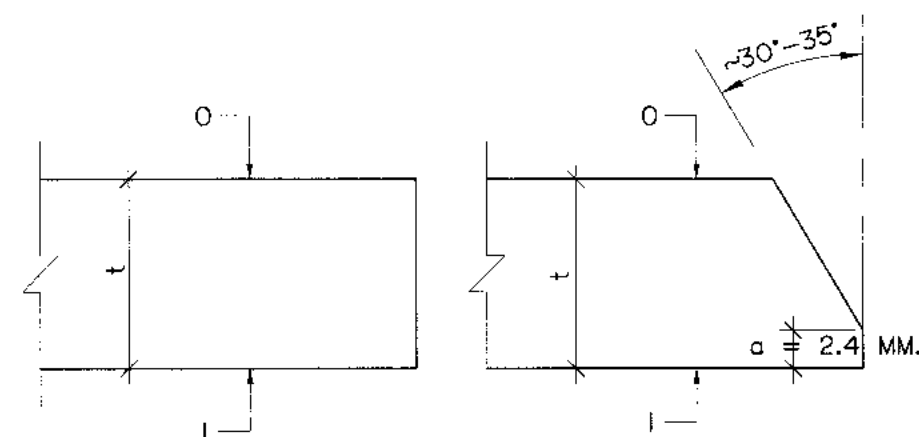

PIPE END DIMENSIONS
NOT TO SCALE

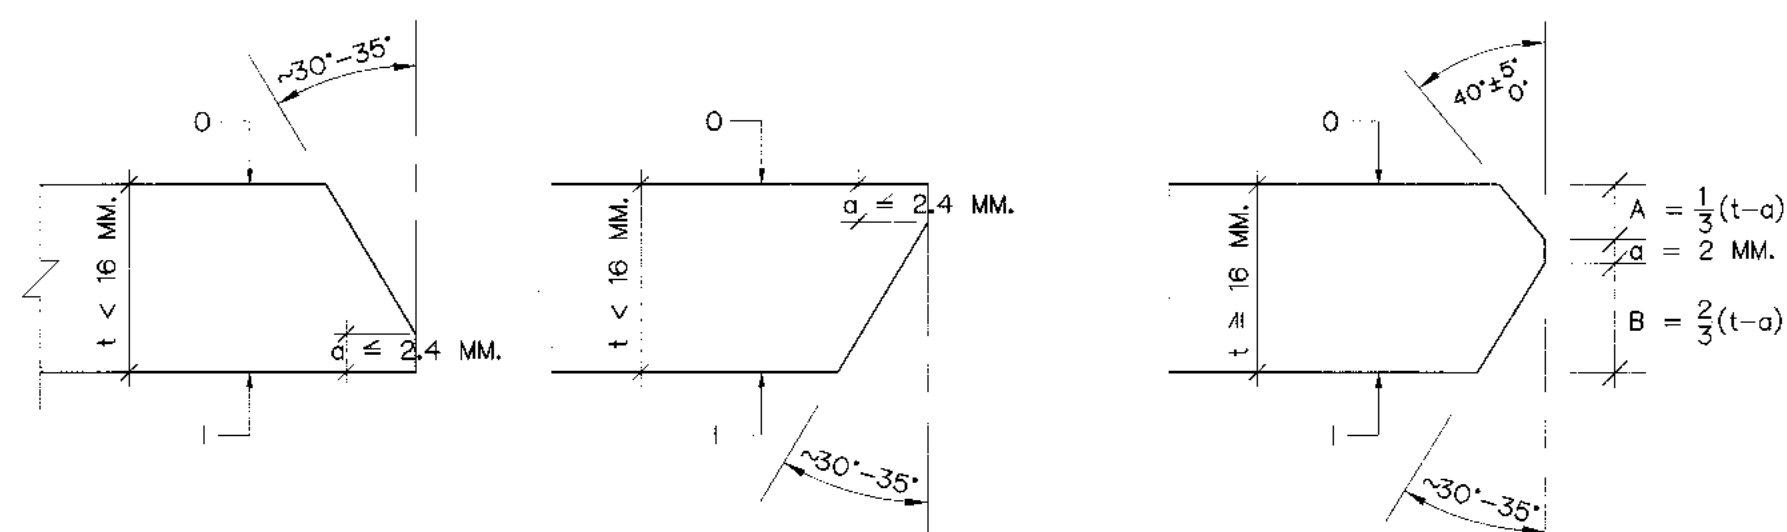


PIPE END DIMENSIONS
FOR D ≥ 800 MM.
NOT TO SCALE

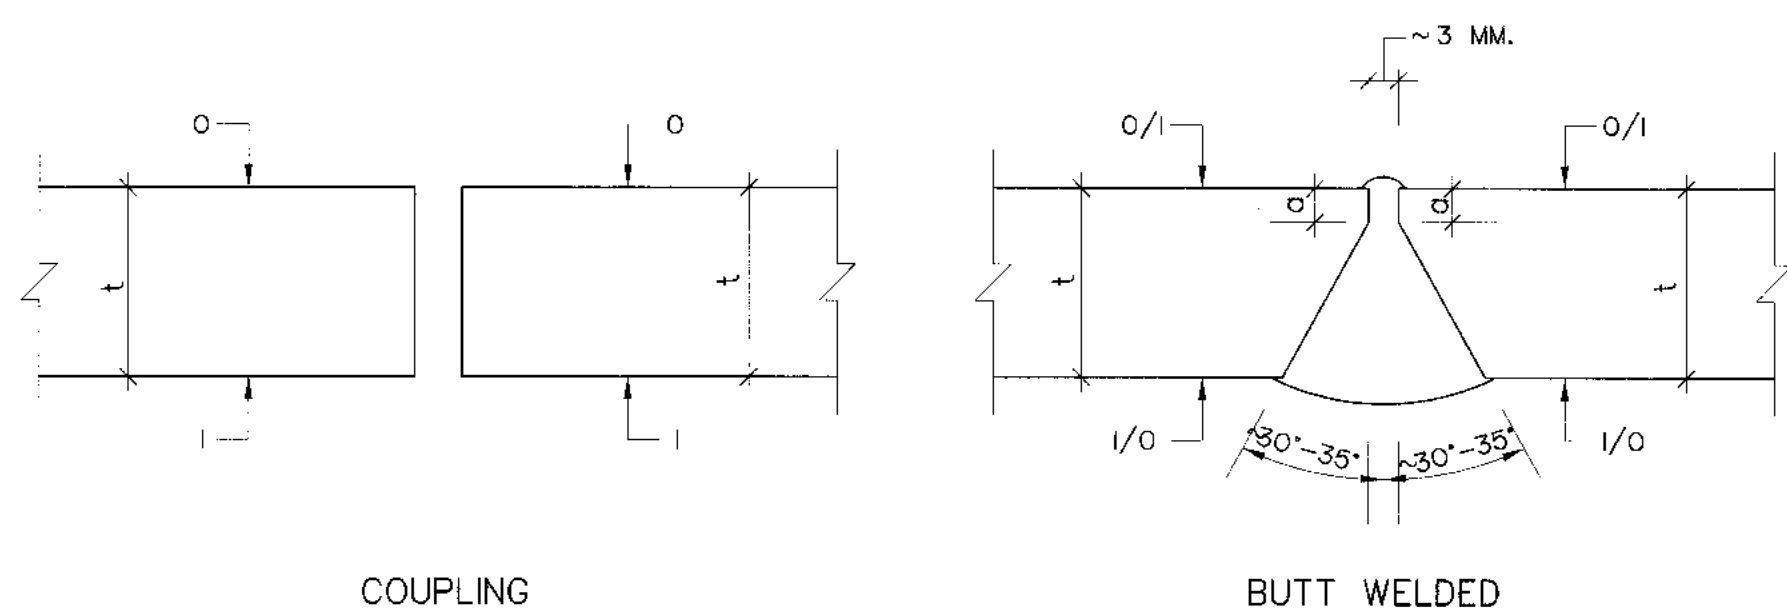

COUPLING


BUTT WELDED

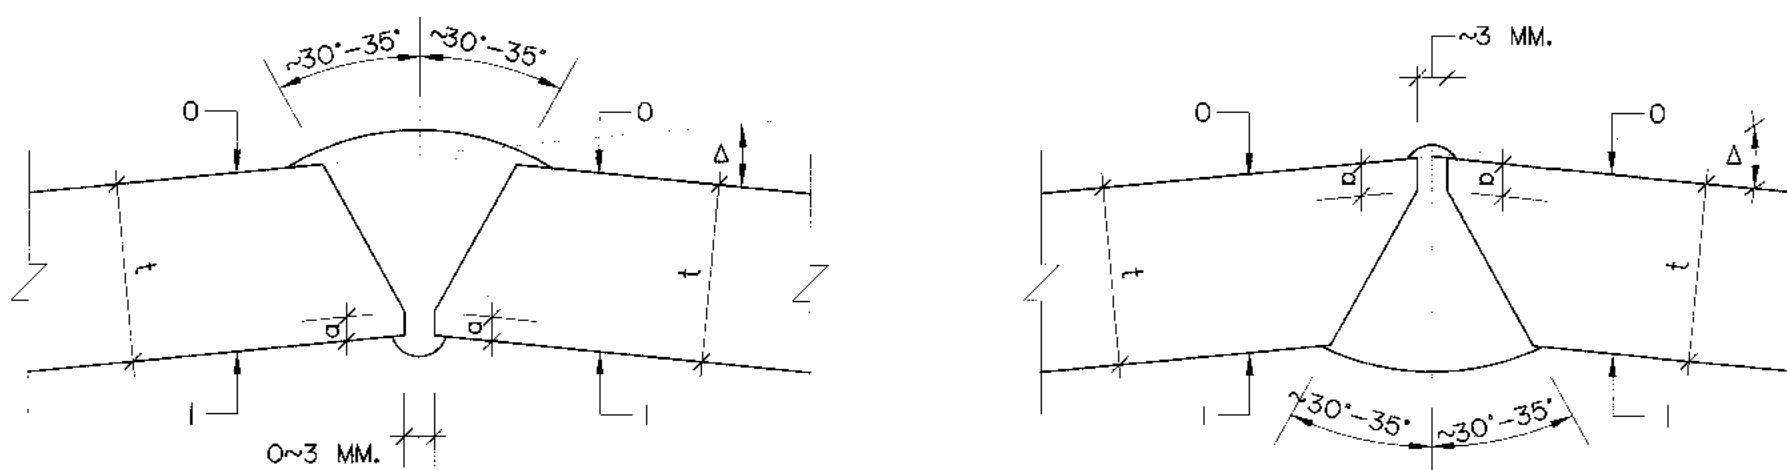


OUTSIDE WELD FOR BEND

INSIDE WELD FOR BEND

DIMENSIONS FOR PIPE CONNECTING
NOT TO SCALE

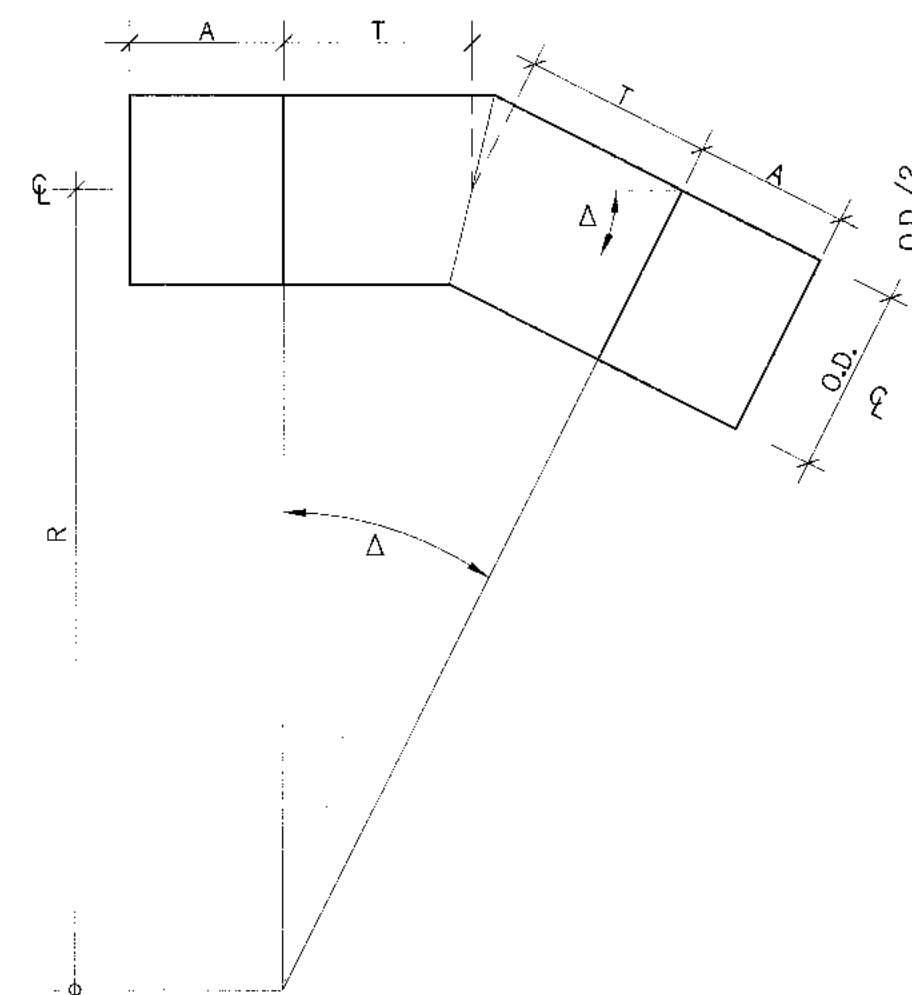

PIPE BEND DETAILED

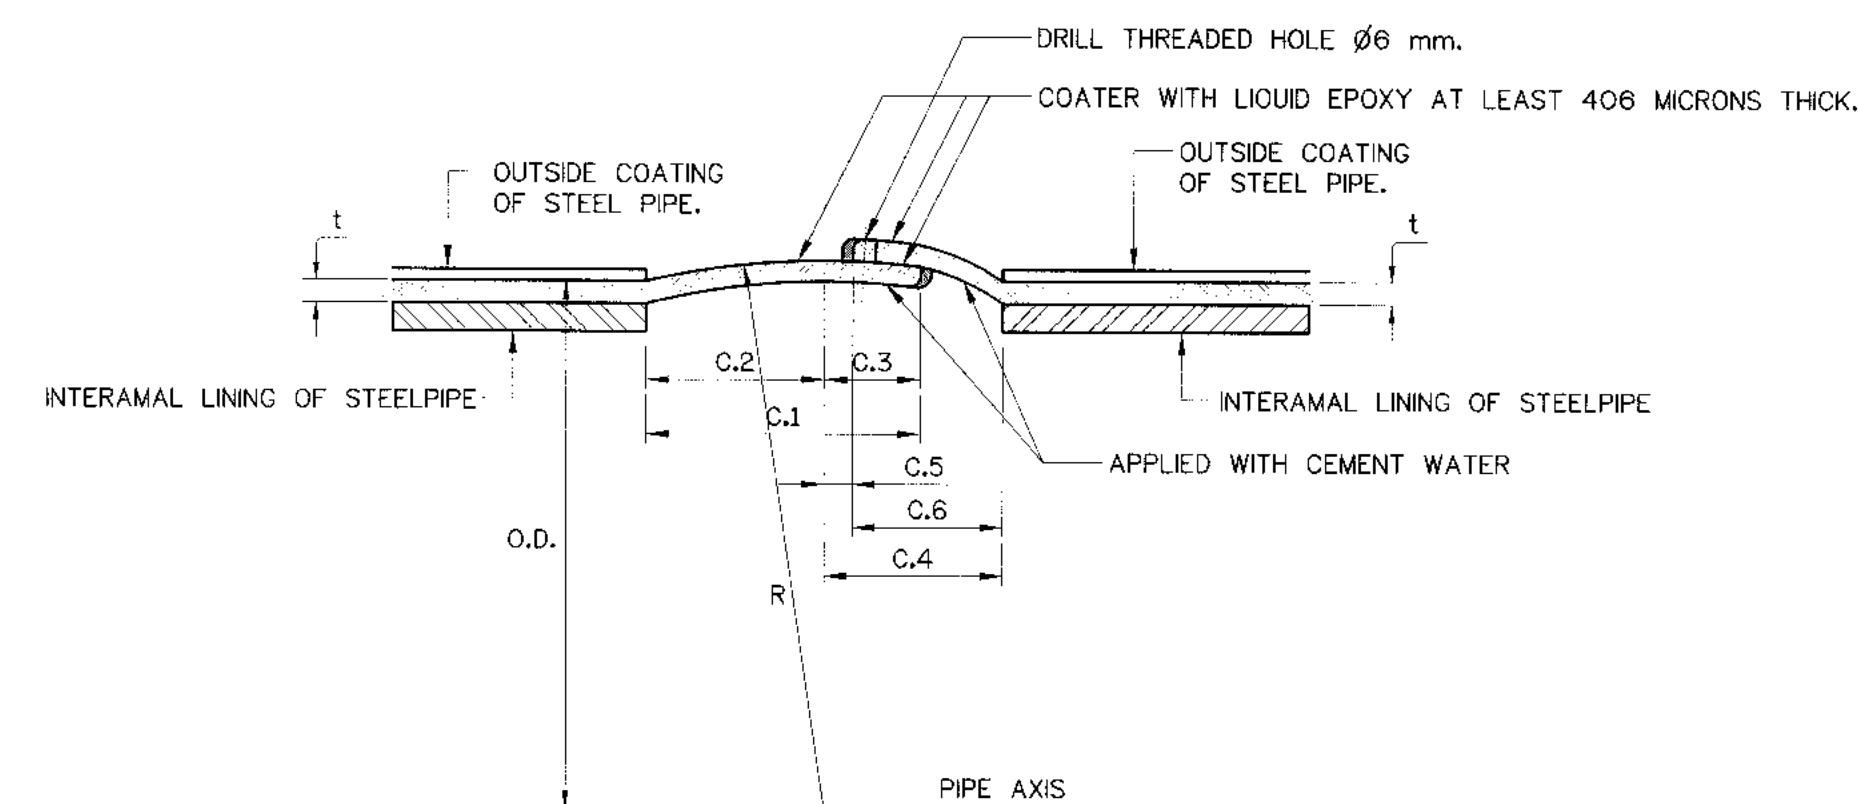

SURFACES SLEEVE WELDED JOINT
NOT TO SCALE

DIMENSIONS IN MILLIMETERS


NOMINAL DIAMETER	OUTSIDE DIA. OD.	THICKNESS t	R	C.1 (C.2 + C.3)	C.2	C.3	C.4 (C.5 + C.6)	C.5	C.6
1,500	1524.0	12.7	796	395	237	158	281	31	250

NOTE :




1. TOLERANCE OUTSIDE CIRCUMFERENCE OF SPIGOT SHALL BE ± 8 mm.
2. TOLERANCE OUTSIDE CIRCUMFERENCE OF SOCKET SHALL BE ± 8 mm.
3. IN CASE OF THE PIPE TO BE COATED INSIDE WITH LIQUID EPOXY THE COATING SHALL EXTEND TO PIPE ENDS.
4. ALL DIMENSIONS IN MILLIMETER, UNLESS OTHERWISE SHOWN.
5. SYMBOLS
 - t = PIPE THICKNESS
 - O.D. = OUTSIDE DIAMETER
 - O = OUTSIDE FACE
 - I = INSIDE FACE
6. Δ SHALL BE LESS THAN 22.5 DEGREE

KINGDOM OF THAILAND Department of Alternative Energy Development and Efficiency MINISTRY OF ENERGY	
KLONG LAM PLOK HYDROPOWER PROJECT	
CIVIL WORKS AND TRANSMISSION LINE HEADRACE STEEL PIPE AND JOINT DETAILS	
DESIGNED <i>[Signature]</i> JIB.29074 DRAWN <i>[Signature]</i> CHECKED <i>[Signature]</i> JIB.6226 PROJECT MANAGER	REVIEWED <i>[Signature]</i> SUBMITTED <i>[Signature]</i> RECOMMENDED <i>[Signature]</i> APPROVED <i>[Signature]</i> P. HANSAKUL DATE 08/03/2559
CONSULTANTS	DEDE


3				
2				
1				
NO.	DATE	REVISIONS	CHECKED	APPROVED

 

H	BXL	T	AS 1	AS 2
$H < 1$	1.80x1.80	0.60	DB16@0.20	DB16@0.20
$1 < H \leq 2$	2.00x2.00	0.60	DB16@0.20	DB16@0.20
$2 < H \leq 3$	2.40x2.20	0.80	DB16@0.20	DB16@0.15
$3 < H \leq 4$	2.60x2.60	0.80	DB16@0.20	DB16@0.15
$4 < H \leq 5$	3.00x2.80	1.00	DB16@0.20	DB20@0.20
$5 < H \leq 6$	3.00x3.00	1.00	DB16@0.20	DB20@0.15

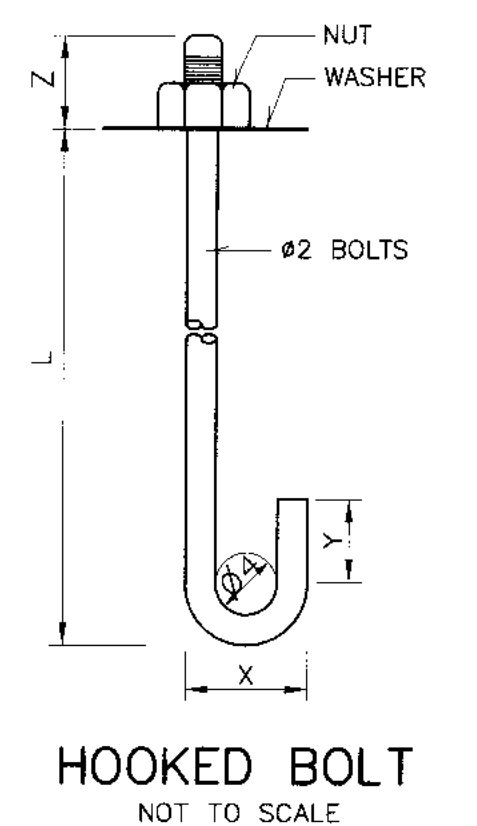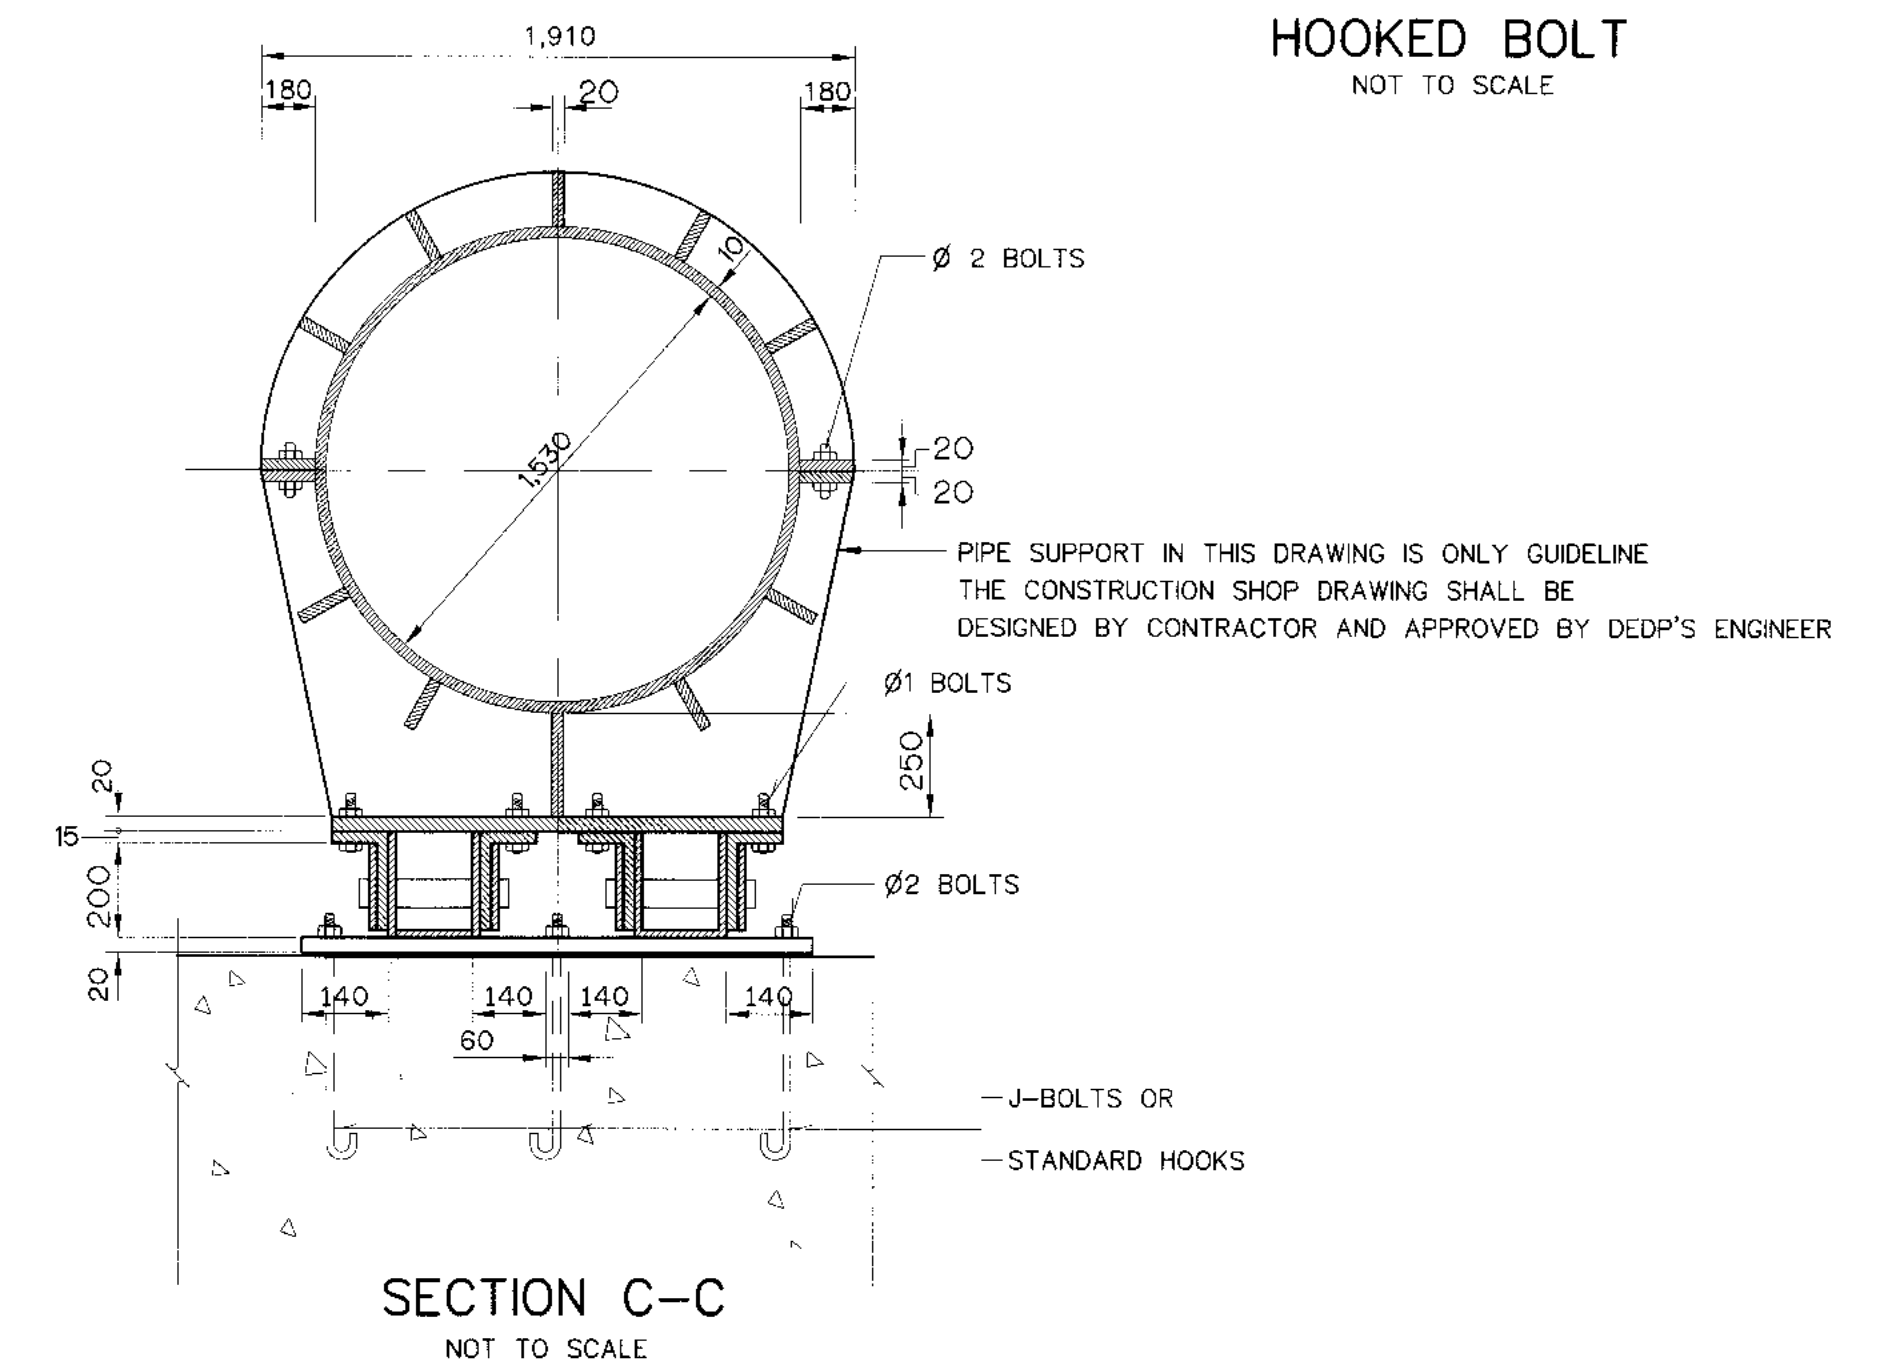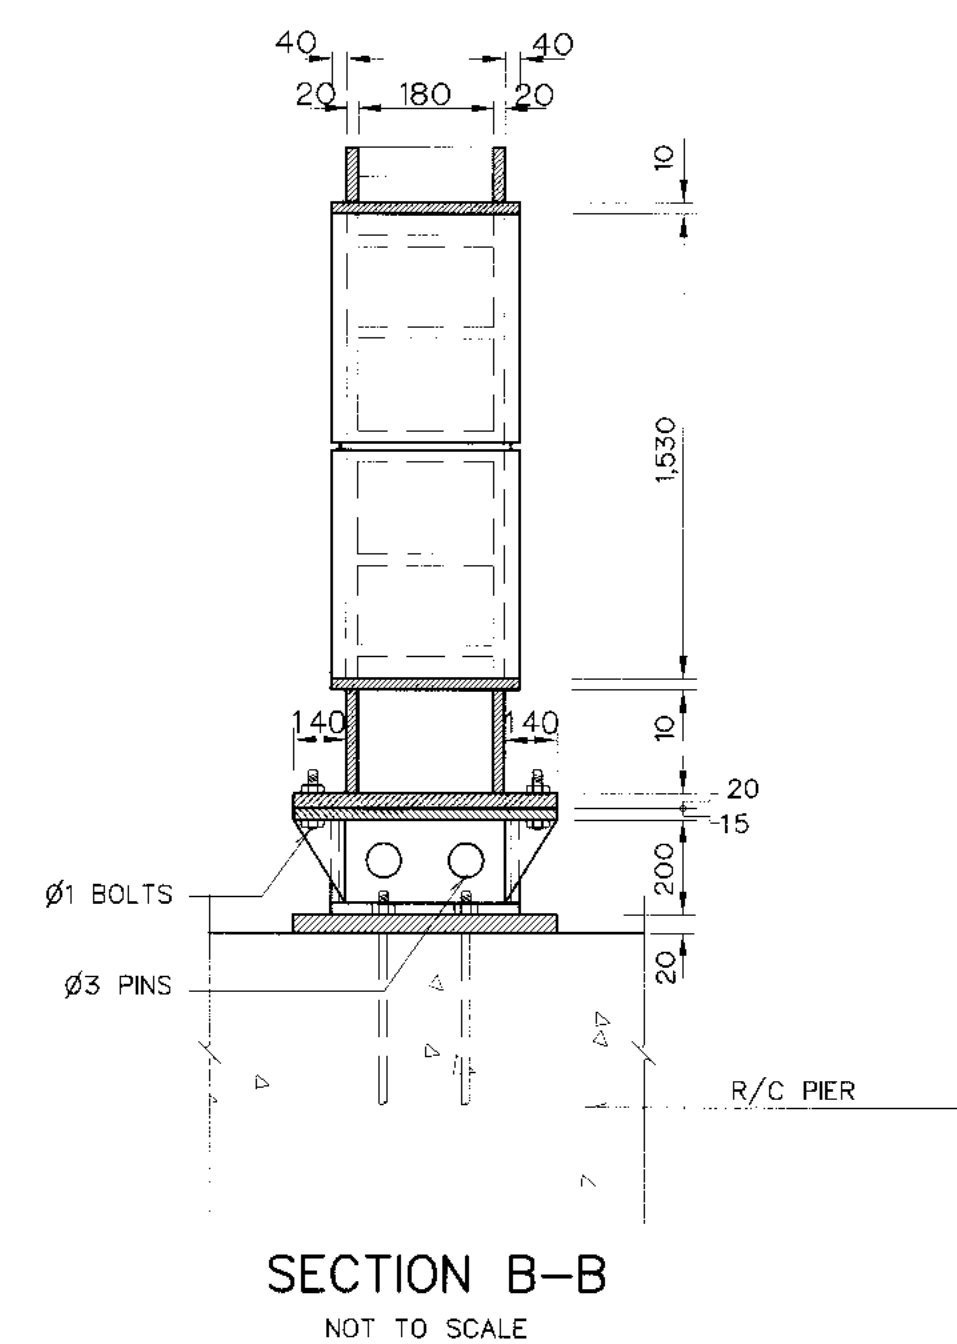


1. DIMENSIONS AND ELEVATIONS (M.S.L.) ARE IN METERS, DIMENSIONS OF PIPE SUPPORT ARE IN MILLIMETERS UNLESS OTHERWISE SHOWN.
2. SYMBOLS, ABBREVIATIONS AND GENERAL NOTES SEE DWG. NO. KLP-GN-03
3. CONCRETE DESIGN BASED ON THE COMPRESSIVE STRENGTH OF 210 KSC, STANDARD CYLINDER $\phi 0.15 \times 0.30$ m. TEST AT AGE 28 DAYS. UNLESS OTHERWISE INDICATED IN SPECIFIC DRAWINGS.
4. ULTIMATE TENSILE STRESSES OF REINFORCING STEEL, CONFORM TO THE REQUIREMENT OF THAI INDUSTRIAL STANDARD DESIGNATION SR24 FOR STRUCTURAL GRADE PLAIN ROUND BAR AND SD30 FOR INTERMEDIATE GRADE DEFORMED BAR.
5. ALLOWABLE BEARING CAPACITY NOT LESS THAN 15 TON/sq m.

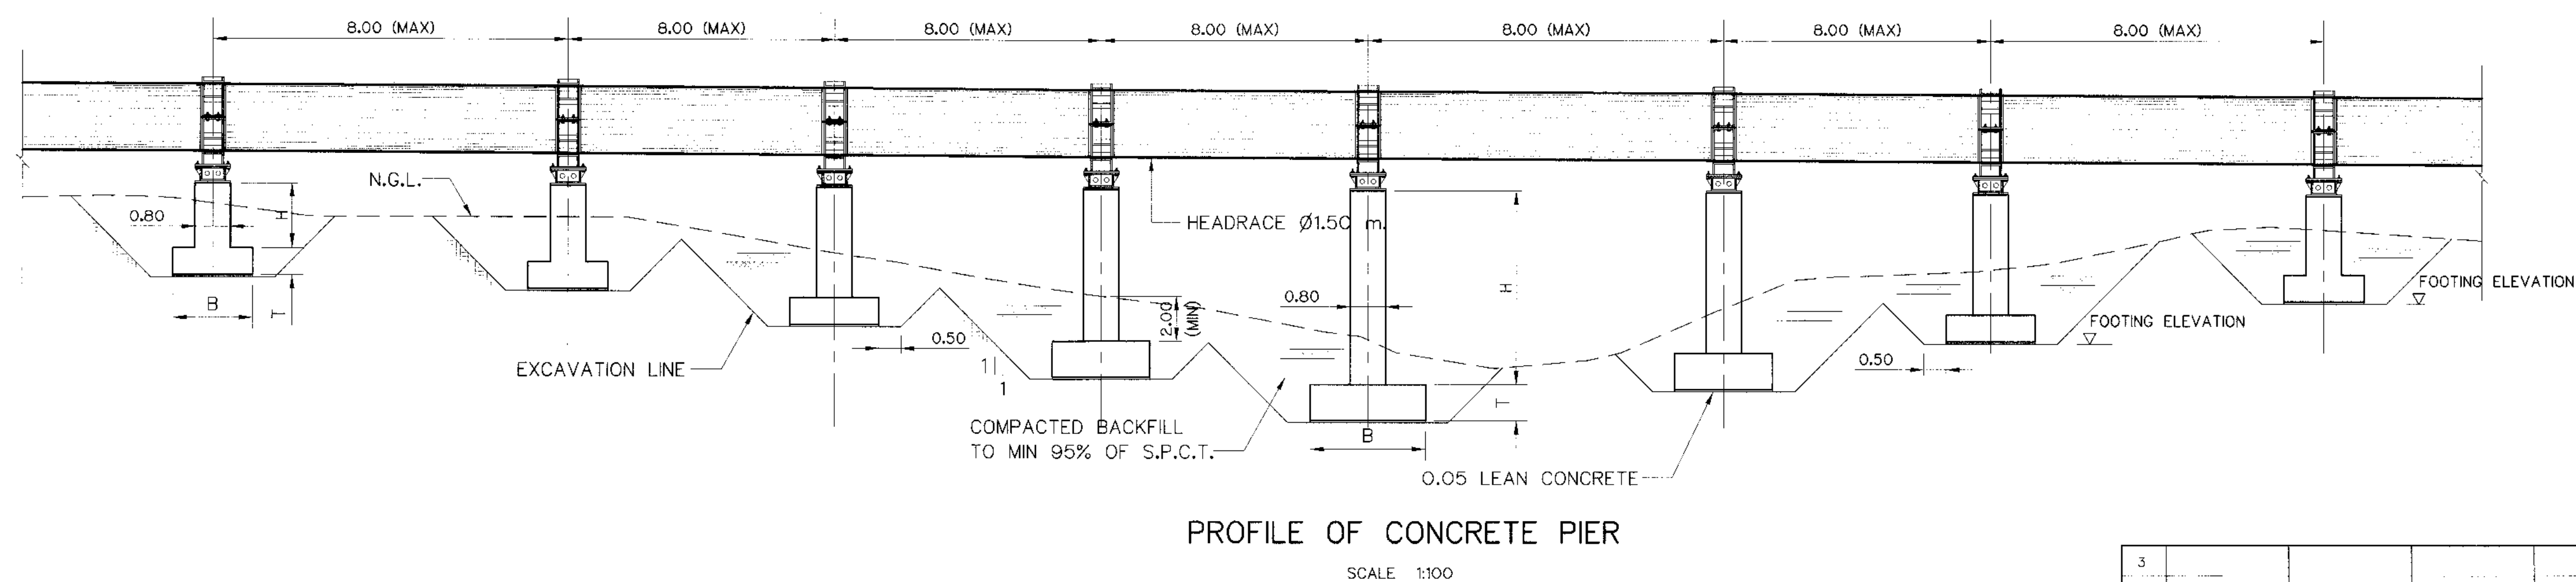



3				
2				
1				
NO.	DATE	REVISIONS	CHECKED	APPROVED
	CONSULTANTS		DEED	

 KINGDOM OF THAILAND Department of Alternative Energy Development and Efficiency MINISTRY OF ENERGY	
KLONG LAM PLOK HYDROPOWER PROJECT	
CIVIL WORKS AND TRANSMISSION LINE HEADRADE CONCRETE PIER SECTION AND DETAILS	
 P&C MANAGEMENT CO.,LTD.	 Department of Alternative Energy Development and Efficiency MINISTRY OF ENERGY
DESIGNED <i>[Signature]</i> SL29074 <i>[Signature]</i> 28.6.226	REVIEWED <i>[Signature]</i>
DRAWN <i>[Signature]</i>	SUBMITTED <i>[Signature]</i>
CHECKED <i>[Signature]</i> 28.6.226	RECOMMENDED <i>[Signature]</i>
<i>OK</i> PROJECT MANAGER 08/03/2559 DATE	DRAWING NO. KLP-HR-08 SHEET NO. 31 OF 110

 


D	ELBOW							
	2-PIECE θ = 11.25°		3-PIECE θ = 22.25°		4-PIECE θ = 45°		5-PIECE θ = 45°	
	M	a	N	b	P	c	Q	d
150	100	250	175	225	275	225	375	250
200	100	250	200	225	300	225	450	250
250	100	250	225	200	350	225	500	250
300	125	275	250	275	400	275	575	300
400	150	350	300	325	500	325	700	350
500	175	350	350	325	550	325	825	350
600	200	350	400	350	650	350	650	350
700	225	400	450	400	725	400	950	375
800	225	475	500	450	800	450	1075	425
900	250	450	525	450	850	425	1175	475
1,000	250	525	550	500	875	500	1250	450
1,200	275	400	575	400	950	375	1300	525
1,500	300	475	675	475	1050	450	1375	400
1,800	325	450	700	425	1150	425	1575	550

  KINGDOM OF SAUDI ARABIA Department of Alternative Energy Development and Efficiency MINISTRY OF ENERGY	
KLONG LAM PLOK HYDROPOWER PROJECT	
CIVIL WORKS AND TRANSMISSION LINE HEADRACE FITTINGS FOR STEEL PIPE	
 P&C MANAGEMENT CO., LTD.	 Department of Alternative Energy Development and Efficiency MINISTRY OF ENERGY
DESIGNED <i>for</i> <i>218.29074</i> <i>0.75</i> <i>261.6226</i>	REVIEWED <i>for</i>
DRAWN <i>for</i>	SUBMITTED <i>for</i>
CHECKED <i>0.75</i> <i>261.6226</i>	RECOMMENDED <i>for</i>
<i>for</i>	APPROVED <i>P. Hammad</i>
 PROJECT MANAGER	DRAWING NO. KLP-HR-09
08/03/2559 DATE	SHEET NO. 32 OF 110

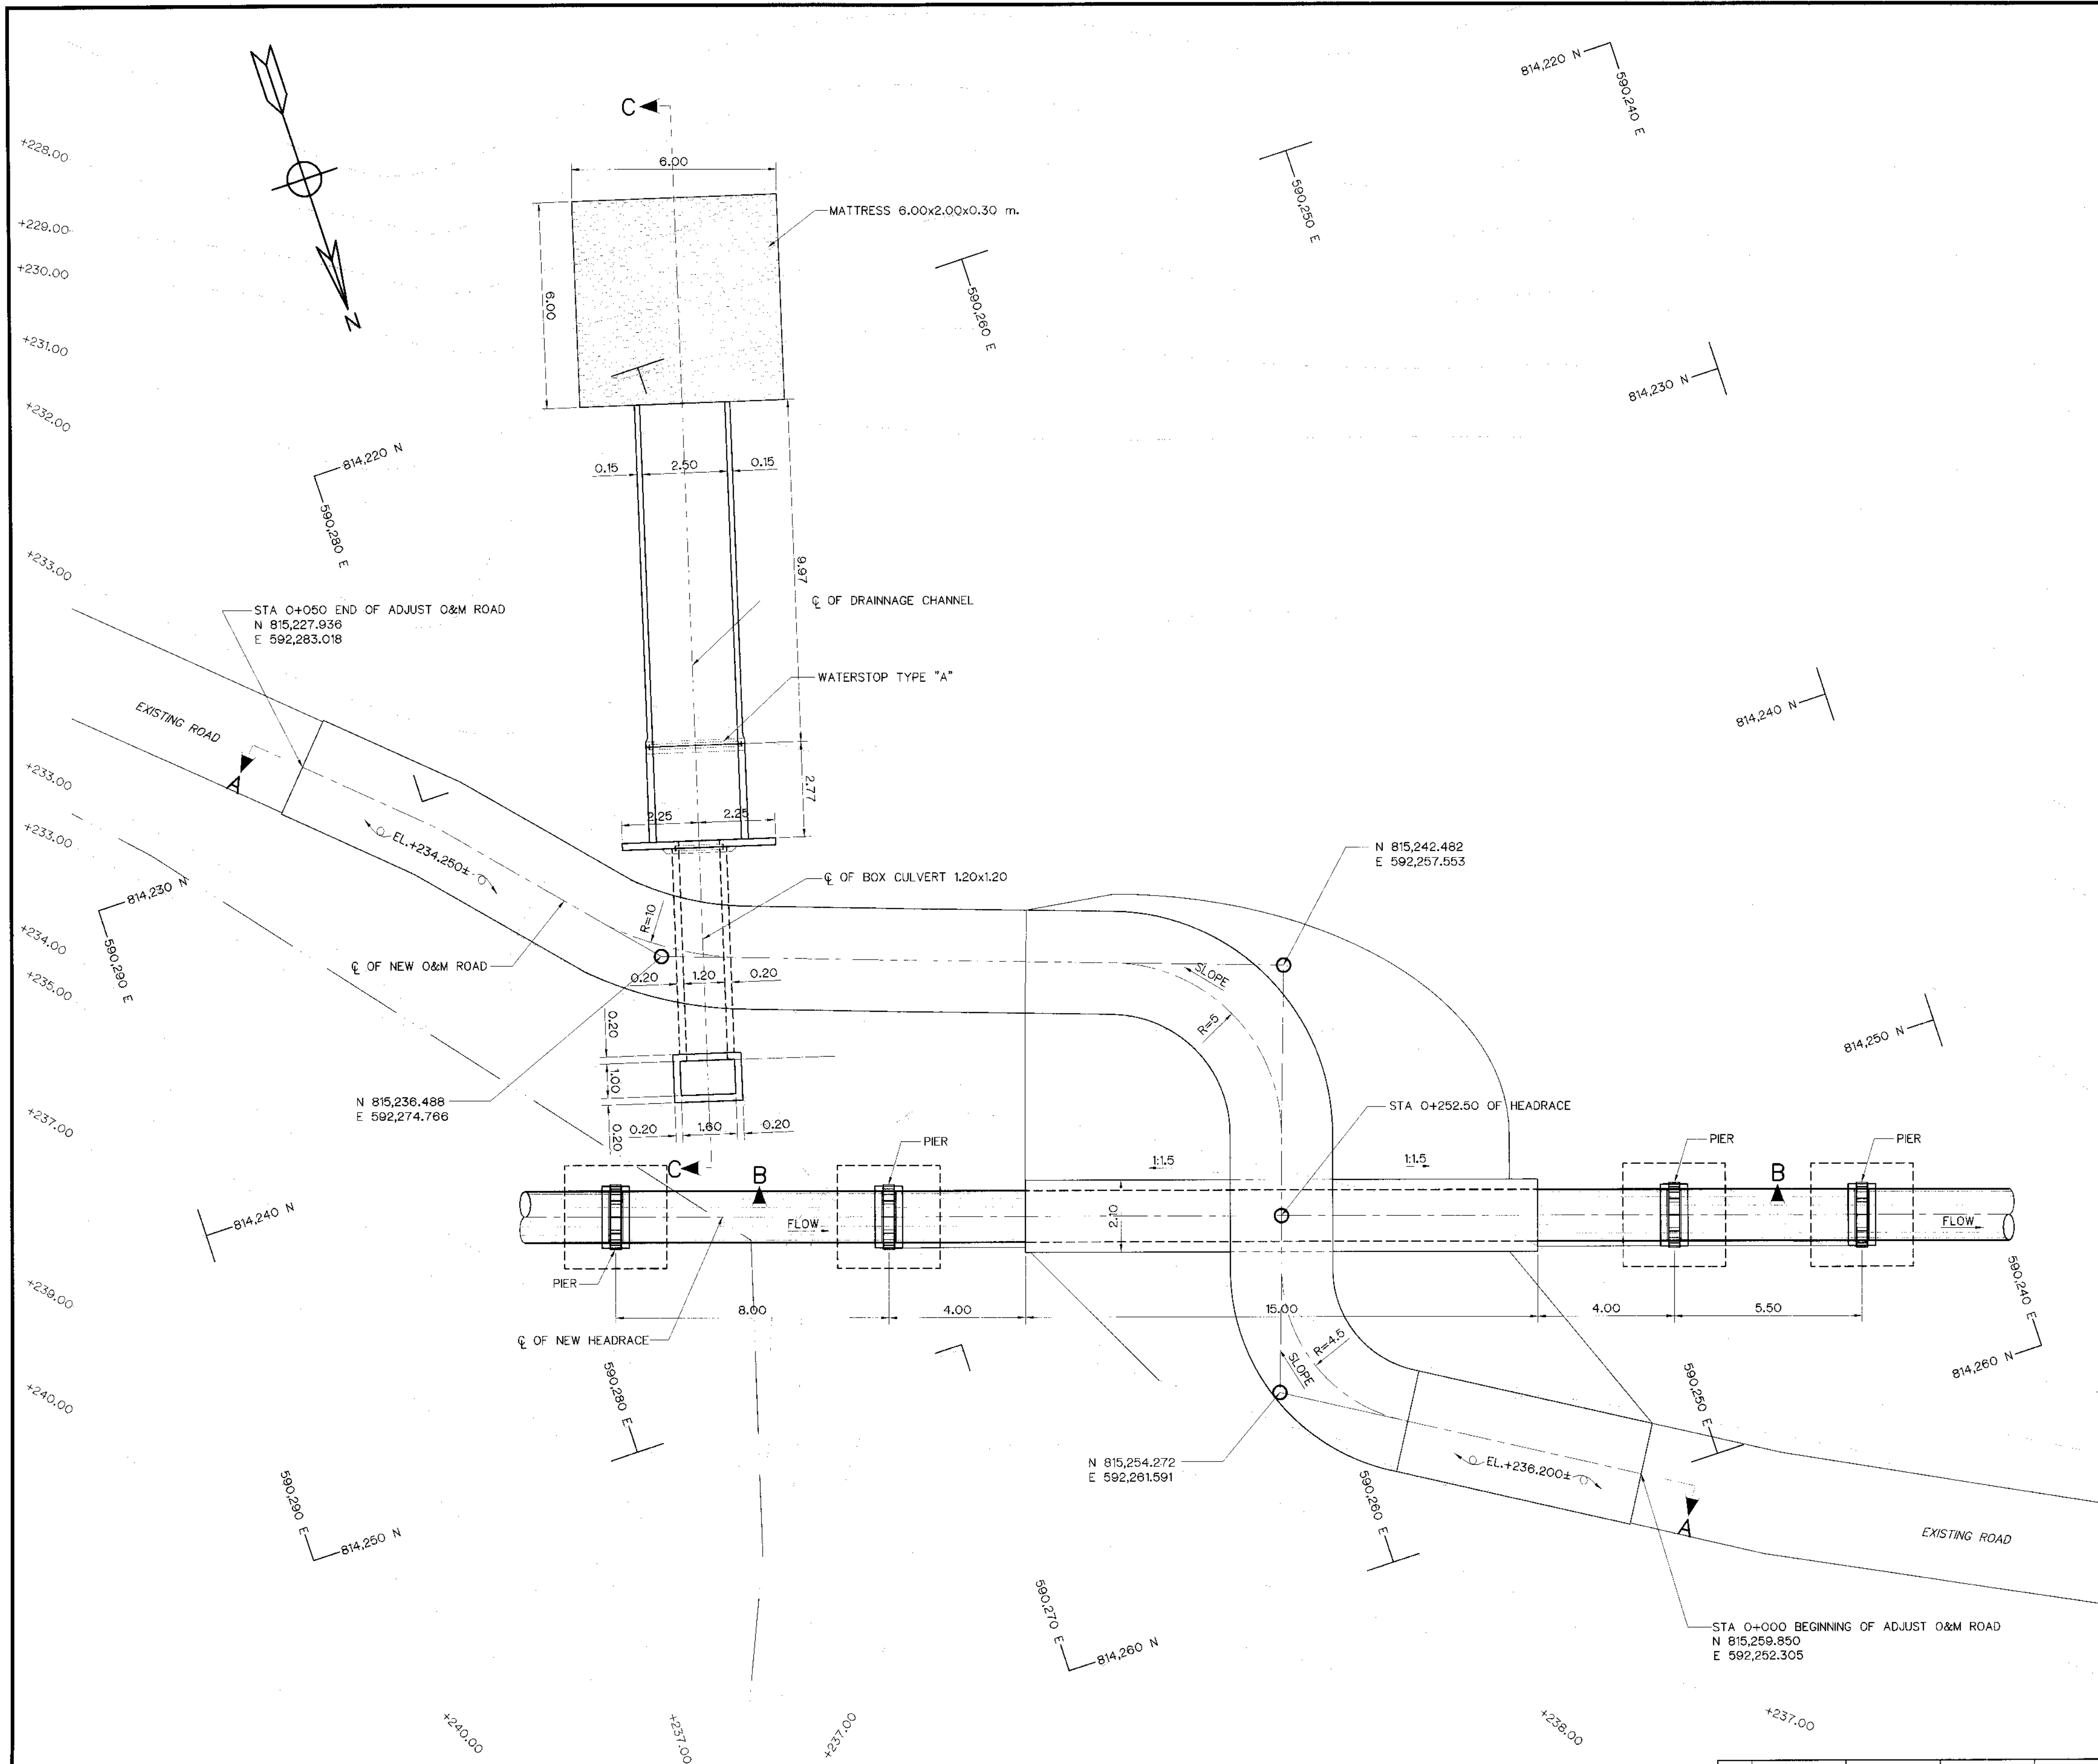




- NOTES :
1. ALL DIMENSIONS AND ELEVATIONS (M.S.L.) ARE IN METERS, UNLESS OTHERWISE SHOWN.
 2. SYMBOLS, ABBREVIATIONS AND GENERAL NOTES SEE DWG. NO. KLP-GN-03
 3. THE ALIGNMENT OF THE HEADRACE AND RELATED STRUCTURES SHALL BE CHECK AND CORRECTED BY THE CONTRACTOR TO SUIT THE FIELD CONDITIONS AND SHALL BE SUBMITTED TO DEDE'S FIELD ENGINEER FOR APPROVAL

- REFERENCE DRAWINGS :
- | | |
|--|-----------|
| 1. HEADRACE PLAN AND PROFILE, STA. 0+000 TO STA. 0+500 | KLP-HR-03 |
| 2. HEADRACE ROAD CROSSING, STA 0+252.50 SECTIONS | KLP-HR-11 |
| 3. HEADRACE CONCRETE PIER SECTION AND DETAILS | KLP-HR-08 |

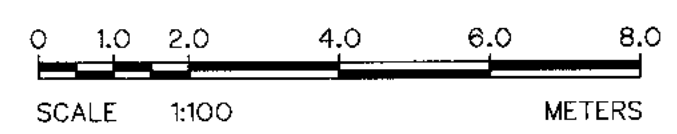

KINGDOM OF THAILAND Department of Alternative Energy Development and Efficiency MINISTRY OF ENERGY	
KLONG LAM PLOK HYDROPOWER PROJECT	
CIVIL WORKS AND TRANSMISSION LINE HEADRACE	
ROAD CROSSING, STA 0+252.50 PLAN	
P&C MANAGEMENT CO.,LTD. DESIGNED: 18/29074 DRAWN: 28/6226 CHECKED: 28/6226 PROJECT MANAGER: 08/03/2559	DEPARTMENT OF ALTERNATIVE ENERGY DEVELOPMENT AND EFFICIENCY MINISTRY OF ENERGY REVIEWED: 28/6226 SUBMITTED: 28/6226 RECOMMENDED: 28/6226 APPROVED: 28/6226 DRAWING NO. KLP-HR-10 SHEET NO. 33 OF 110

PLAN
SCALE 1:100

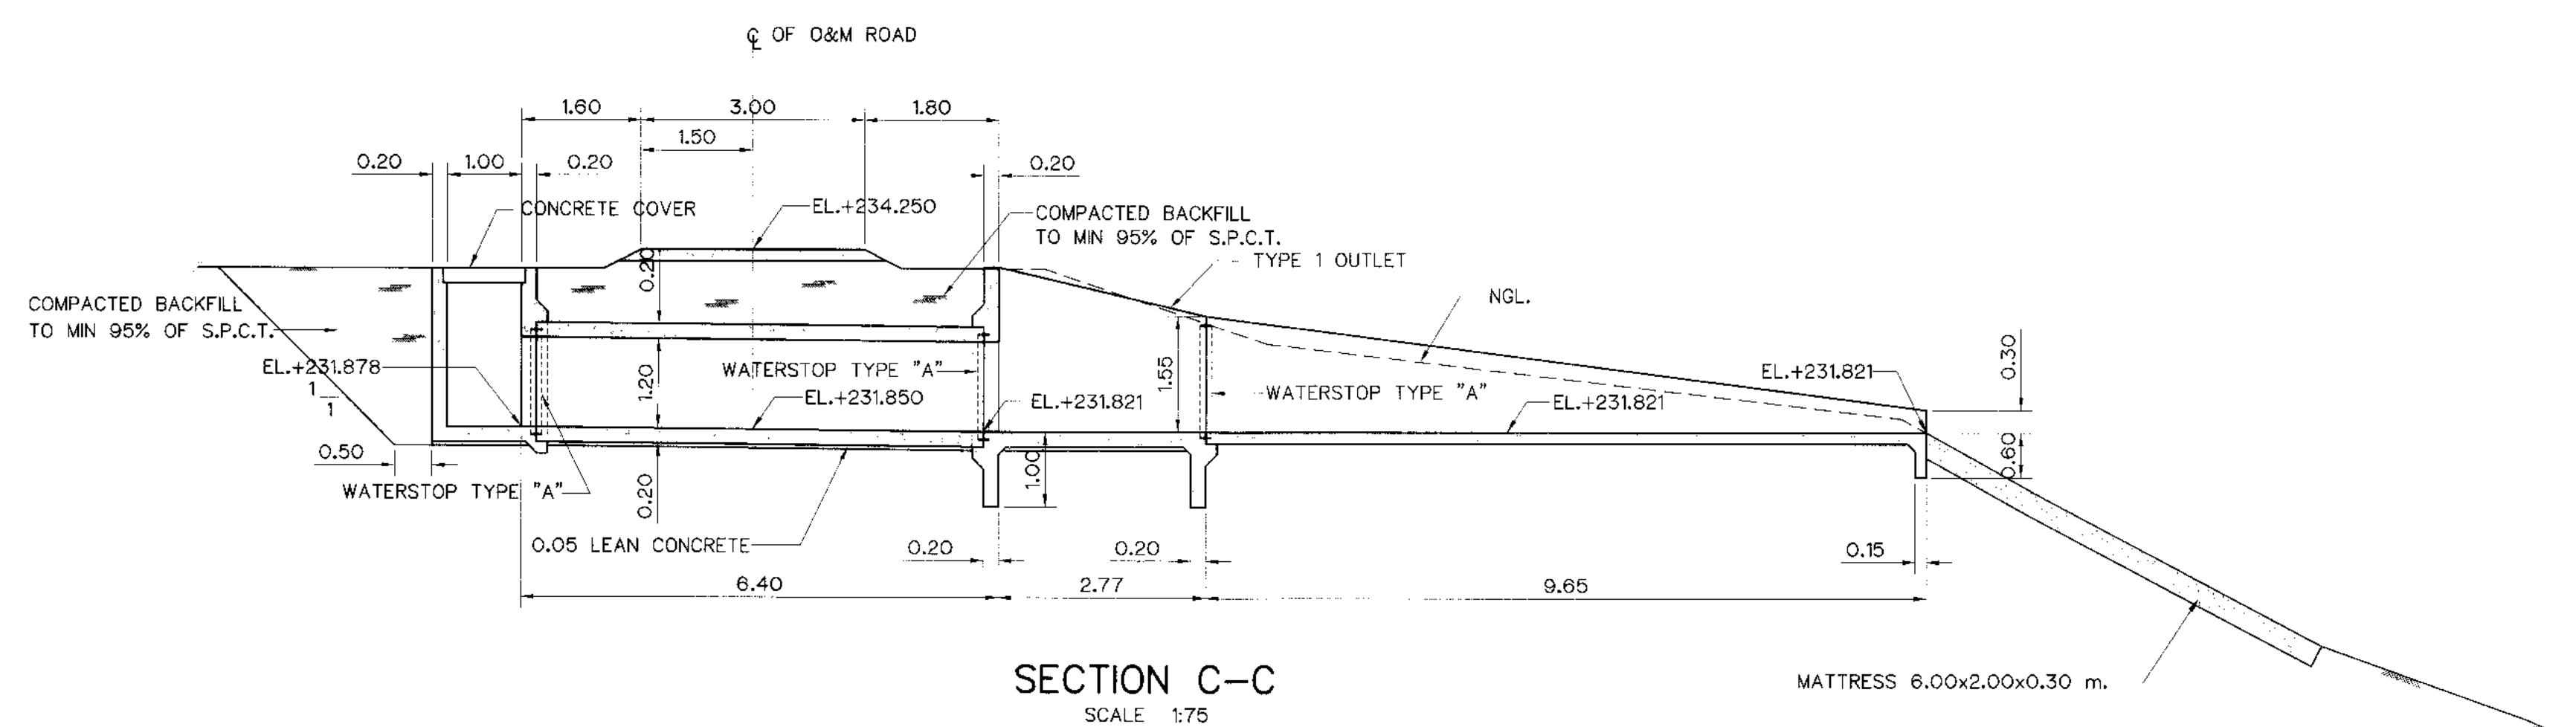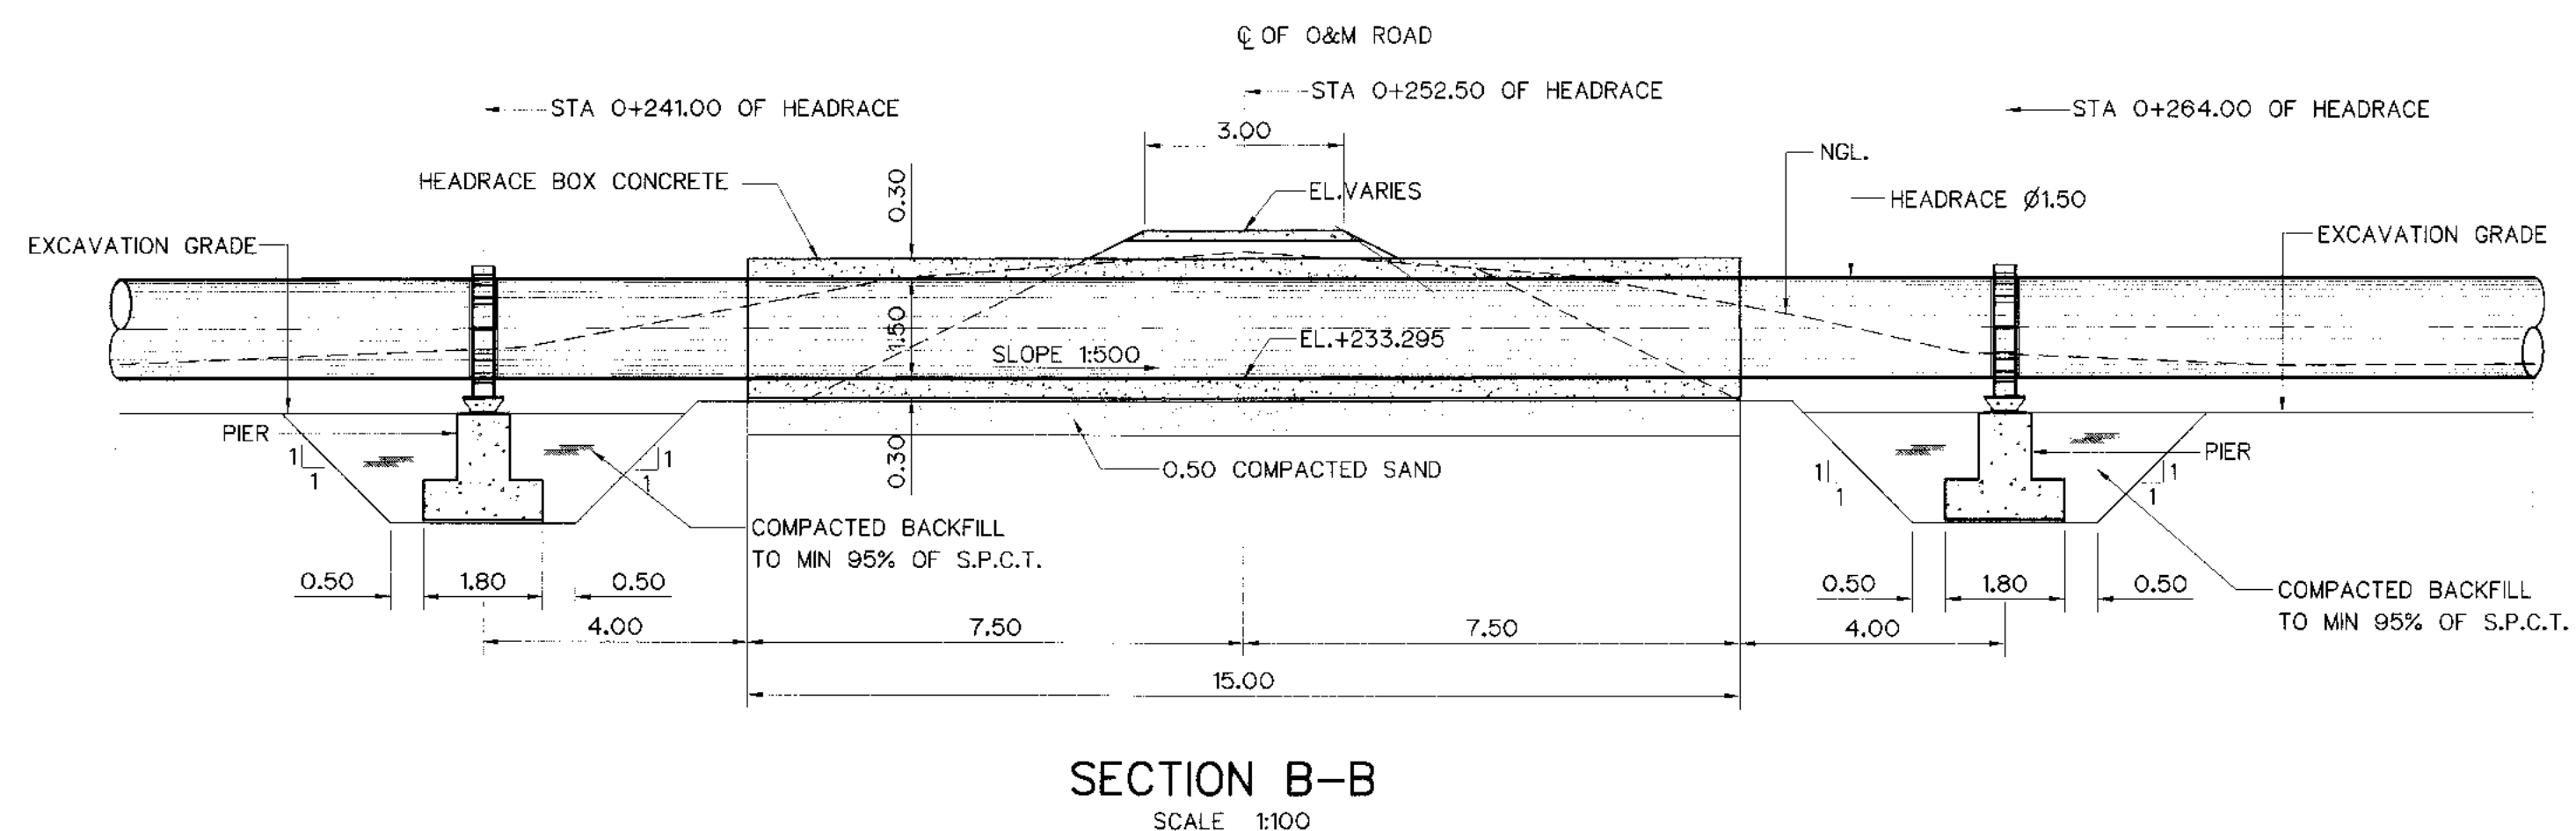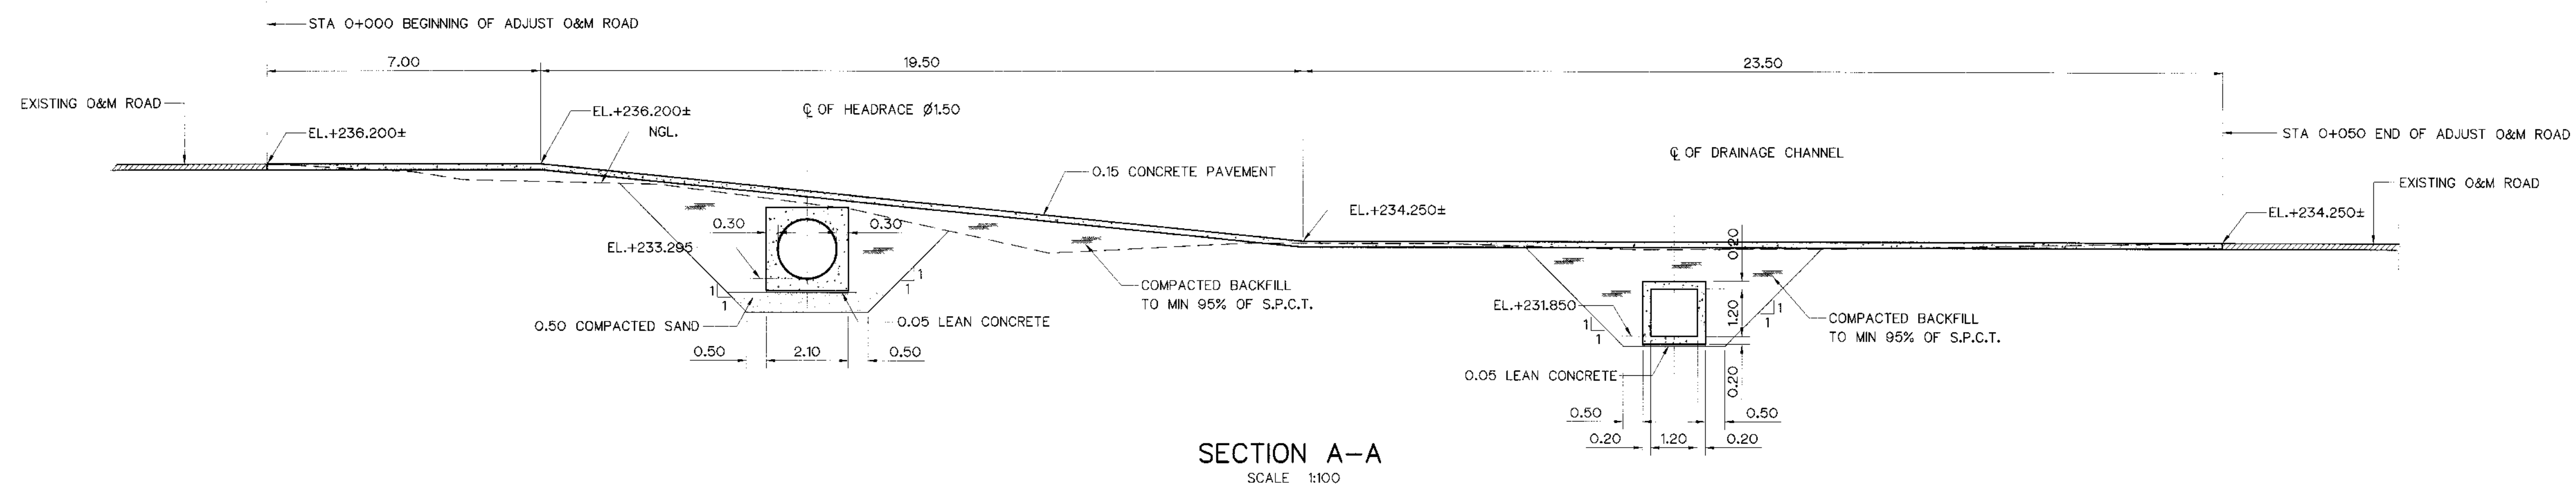


NOTES :


1. ALL DIMENSIONS AND ELEVATIONS (M.S.L.) ARE IN METERS, UNLESS OTHERWISE SHOWN.
2. SYMBOLS, ABBREVIATIONS AND GENERAL NOTES SEE DWG. NO. KLP-GN-03
3. THE ALIGNMENT OF THE HEADRACE AND RELATED STRUCTURES SHALL BE CHECK AND CORRECTED BY THE CONTRACTOR TO SUIT THE FIELD CONDITIONS AND SHALL BE SUBMITTED TO DEDE'S FIELD ENGINEER FOR APPROVAL

REFERENCE DRAWINGS :

1. HEADRACE ROAD CROSSING, STA 0+252.50 PLAN KLP-HR-10
2. HEADRACE BOX CONCRETE KLP-HR-06
3. INLET AND OUTLET TRANSITION KLP-HR-21

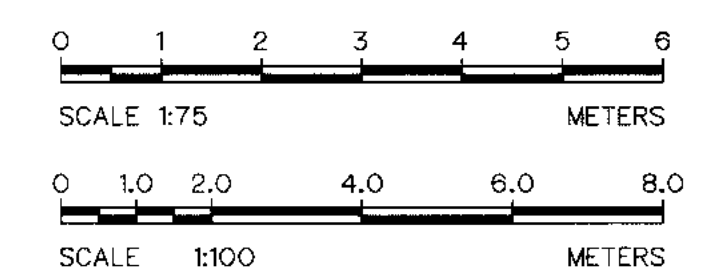

KINGDOM OF THAILAND Department of Alternative Energy Development and Efficiency MINISTRY OF ENERGY	
KLONG LAM PLOK HYDROPOWER PROJECT	
CIVIL WORKS AND TRANSMISSION LINE HEADRACE ROAD CROSSING, STA 0+252.50 SECTIONS	
DESIGNED DRAWN CHECKED PROJECT MANAGER	REVIEWED SUBMITTED RECOMMENDED APPROVED DATE
NO. DATE REVISIONS CHECKED APPROVED CONSULTANTS DEDE	DRAWING NO. SHEET NO. KLP-HR-11 34 OF 110


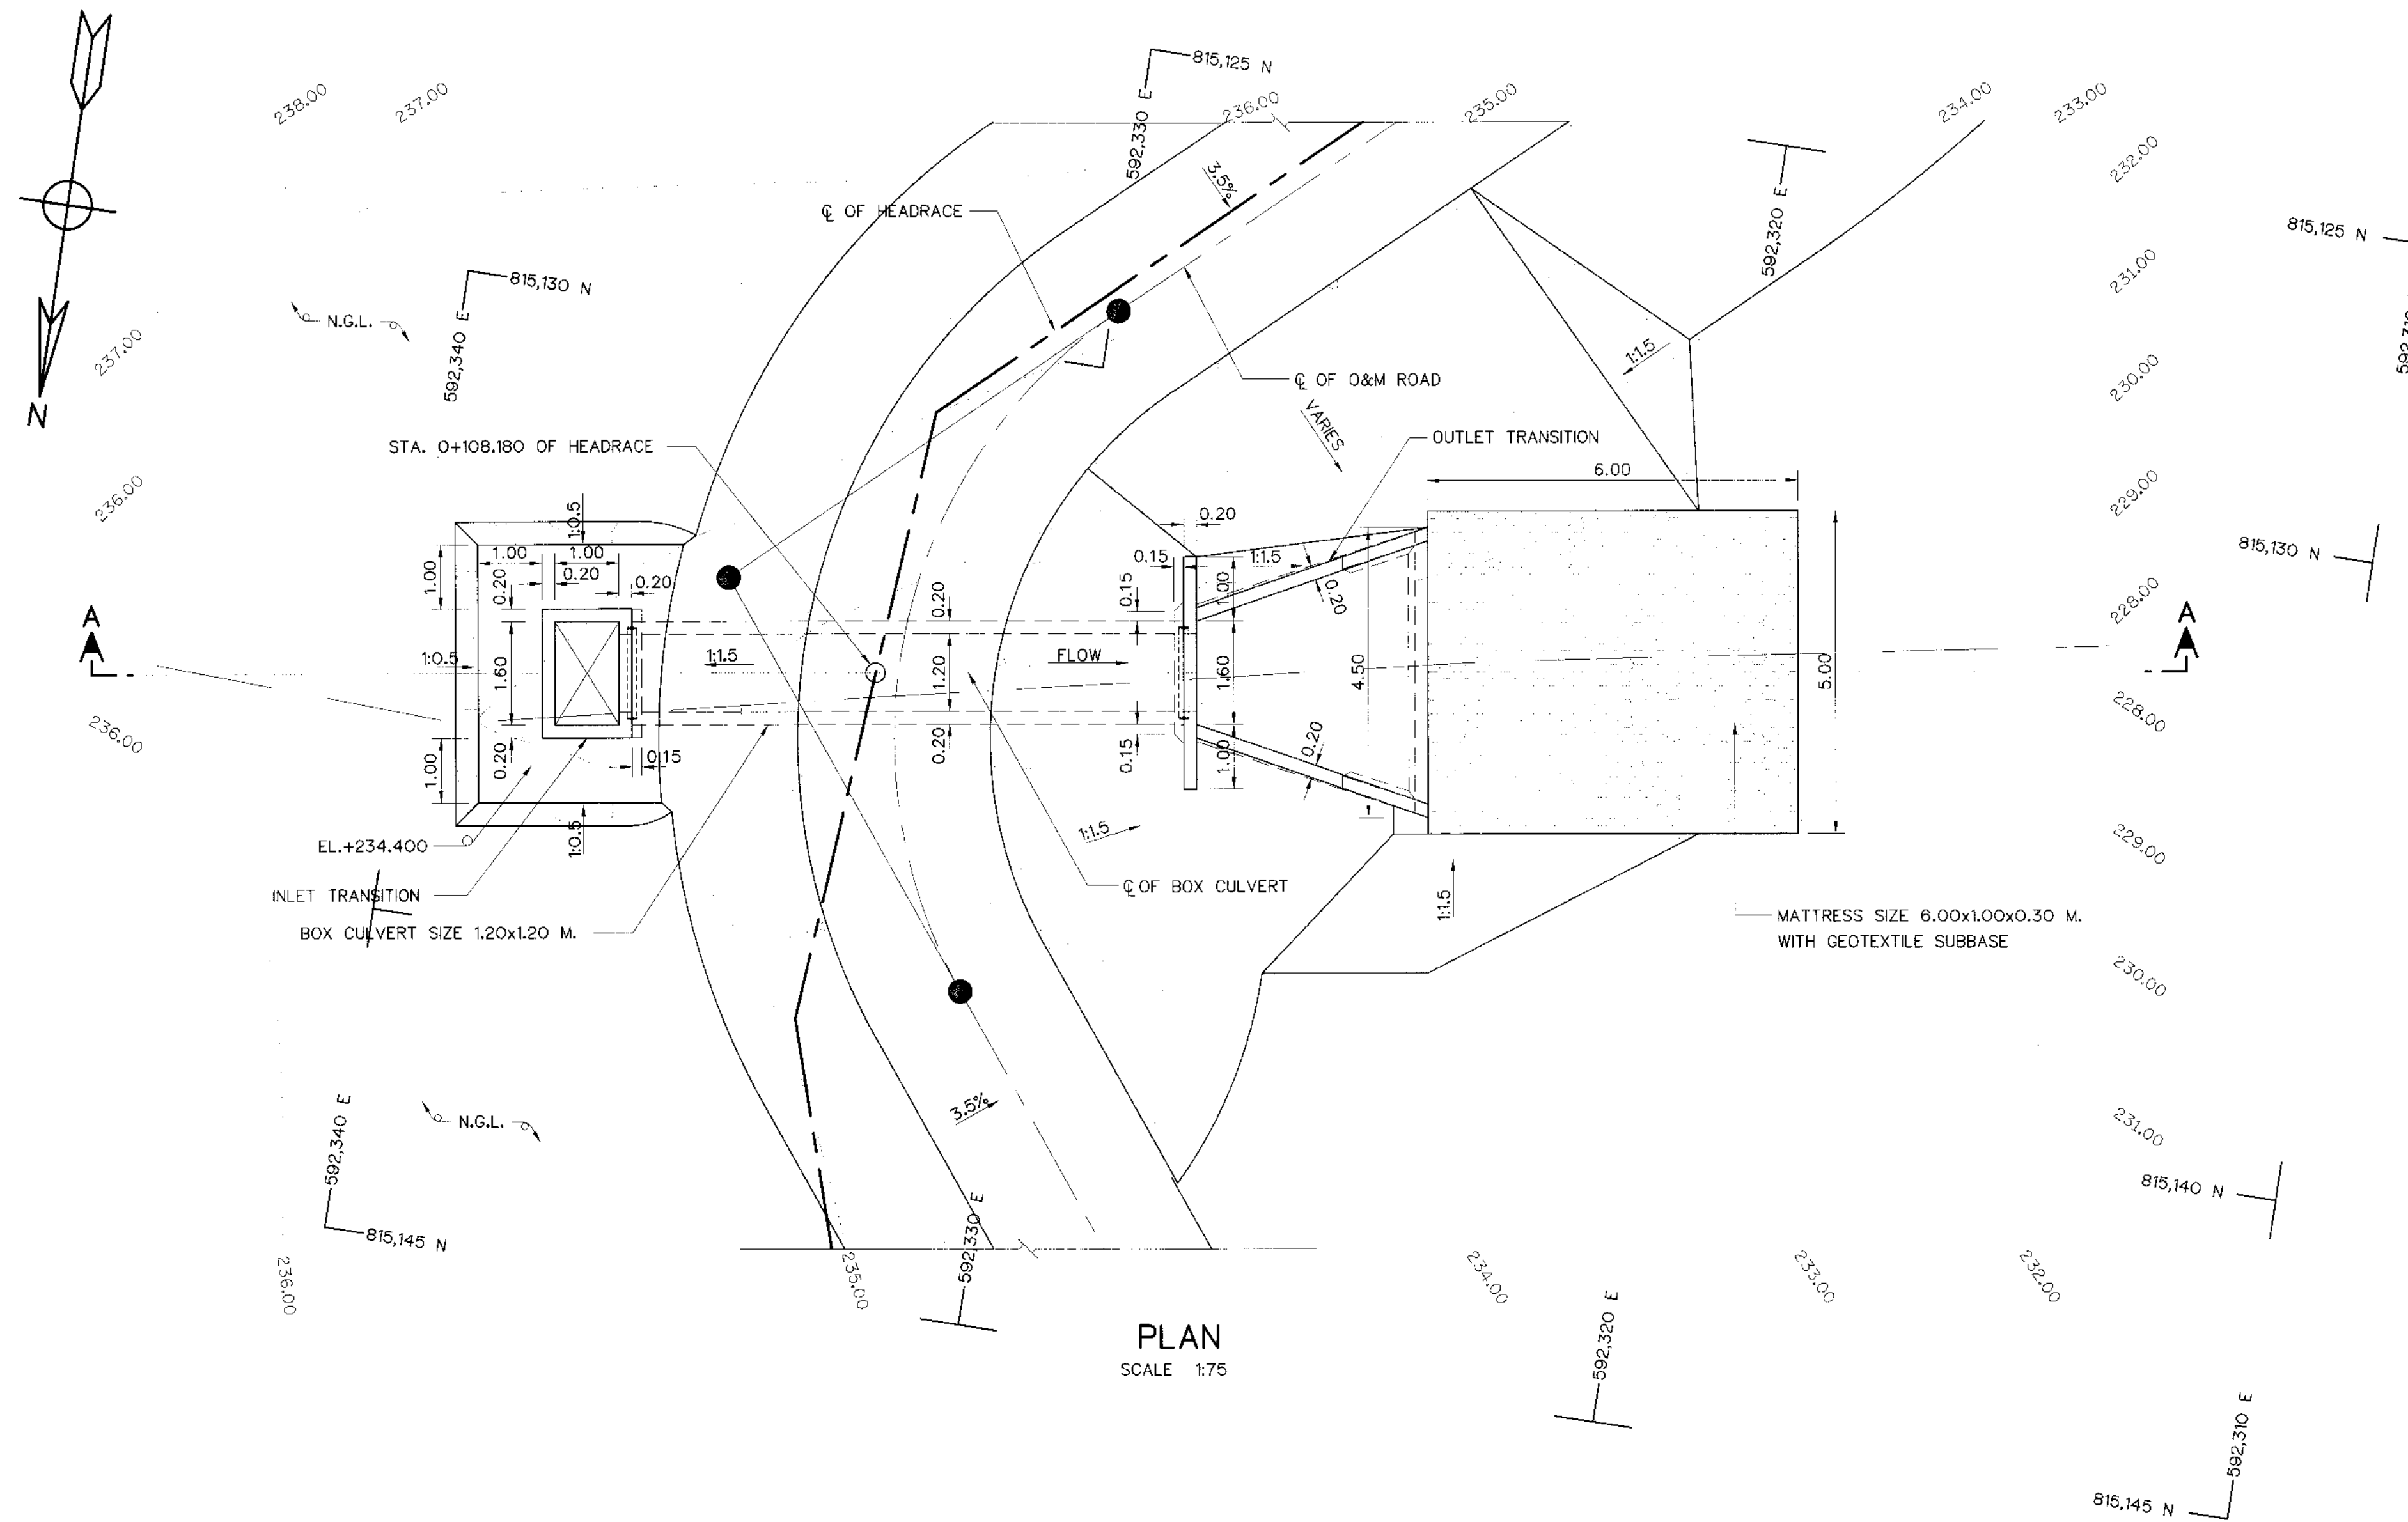


NOTES :

1. ALL DIMENSIONS AND ELEVATIONS (M.S.L.) ARE IN METERS, UNLESS OTHERWISE SHOWN.
2. SYMBOLS, ABBREVIATIONS AND GENERAL NOTES SEE DWG. NO. KLP-GN-03
3. THE ALIGNMENT OF THE HEADRACE AND RELATED STRUCTURES SHALL BE CHECK AND CORRECTED BY THE CONTRACTOR TO SUIT THE FIELD CONDITIONS AND SHALL BE SUBMITTED TO DEDE'S FIELD ENGINEER FOR APPROVAL


REFERENCE DRAWINGS :

1. HEADRACE PLAN AND PROFILE, STA. 0+000 TO STA. 0+500 KLP-HR-03
2. HEADRACE DRAIN CULVERT DETAILS OF REINFORCEMENT KLP-HR-21
3. HEADRACE TYPICAL SECTIONS AND DETAIL KLP-HR-06

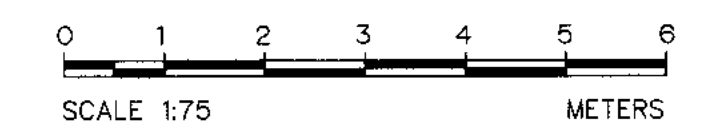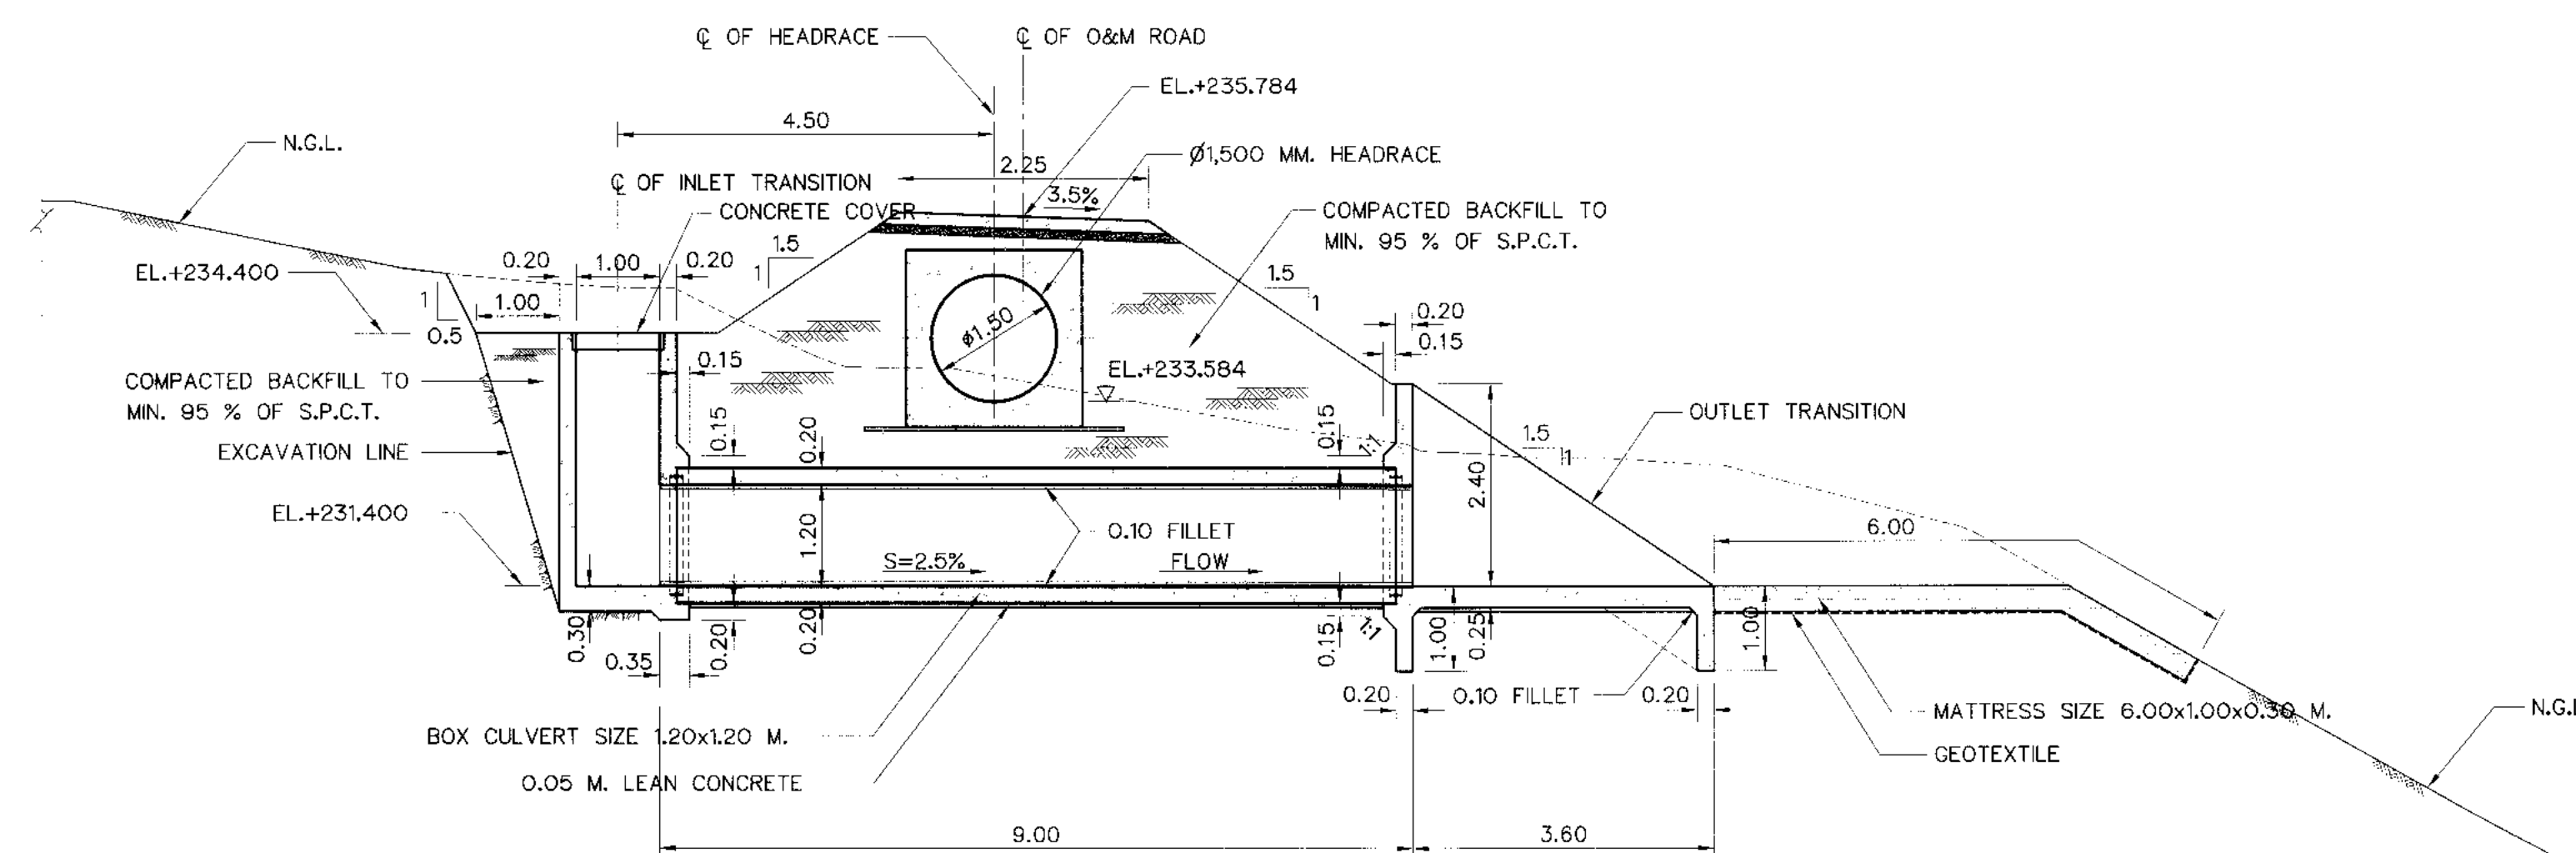

KINGDOM OF THAILAND Department of Alternative Energy Development and Efficiency MINISTRY OF ENERGY	
KLONG LAM PLOK HYDROPOWER PROJECT	
CIVIL WORKS AND TRANSMISSION LINE HEADRACE DRAIN CULVERT STA. 0+108.180 , PLAN AND SECTION	
DESIGNED <i>W. 281.28074</i> 09/281.6226	REVIEWED <i>Chenit</i>
DRAWN <i>gma</i>	RECOMMENDED <i>gma</i>
CHECKED <i>gma</i> 09/281.6226	APPROVED <i>P. Howell</i>
PROJECT MANAGER <i>gma</i> 08/03/2559	DRAWING NO. KLP-HR-13
DATE	SHEET NO. 36 OF 110

NO.	DATE	REVISIONS	CHECKED	APPROVED
3				
2				
1				
CONSULTANTS		DEDE		


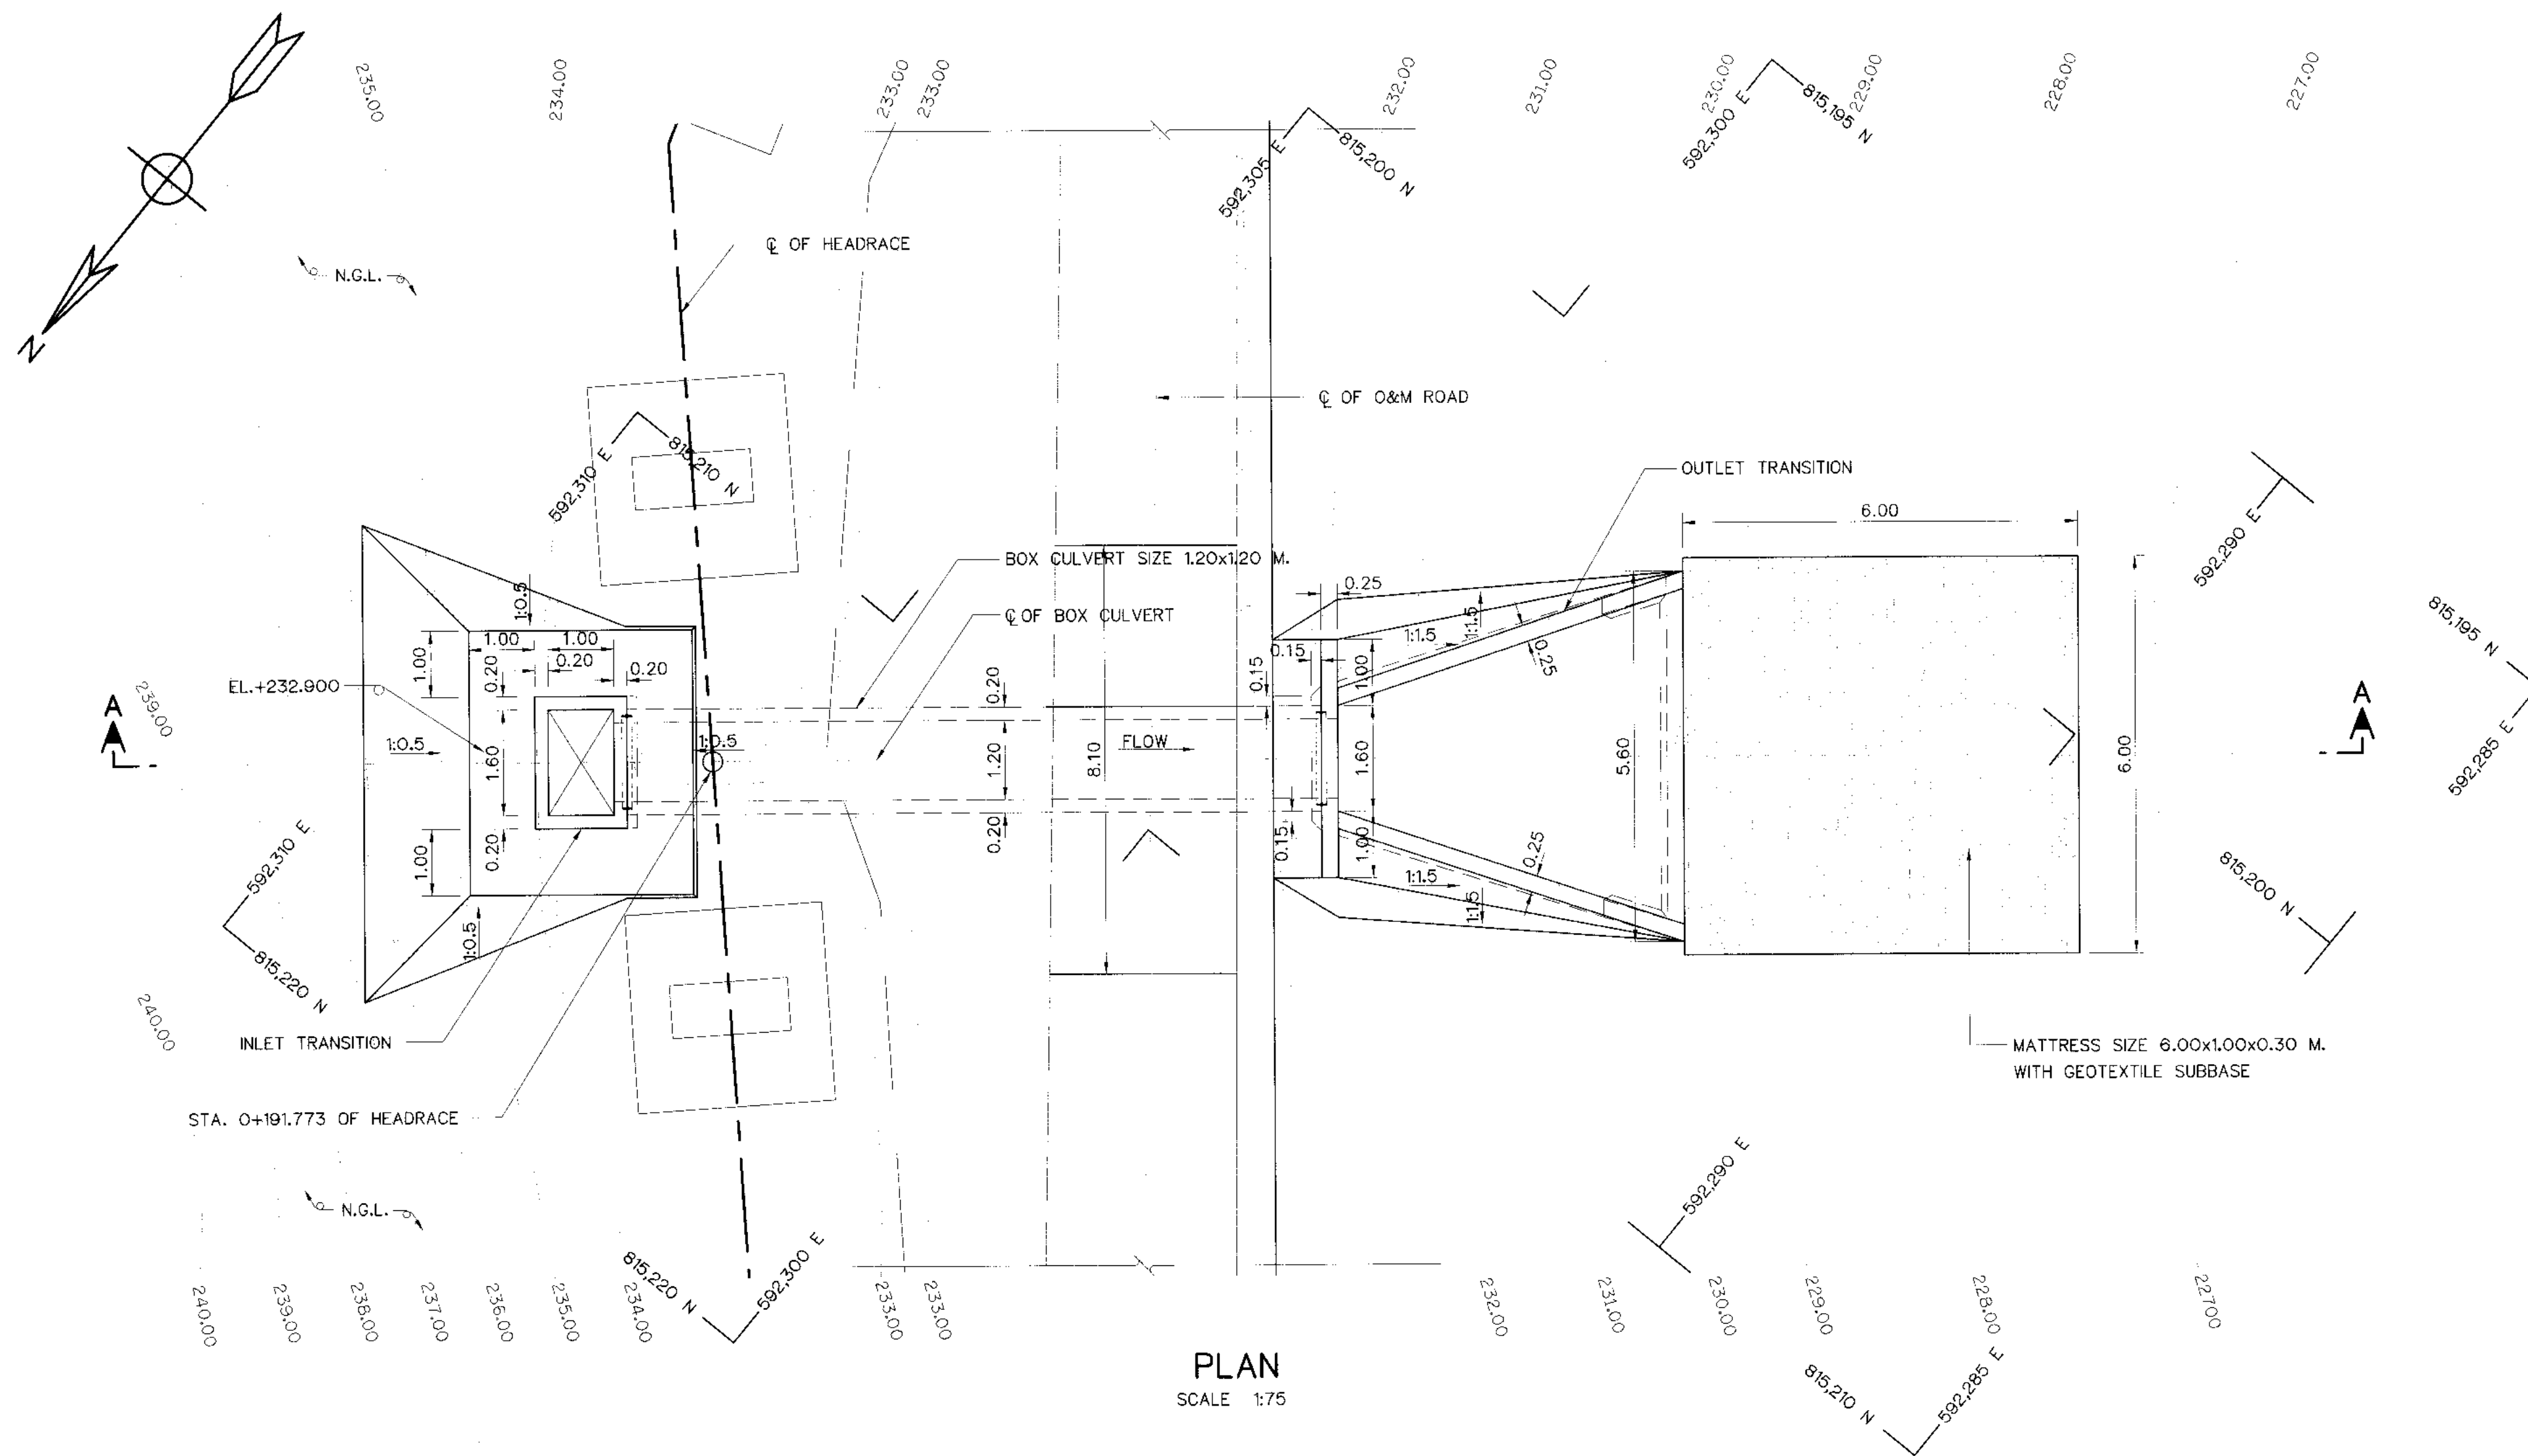


NOTES :

1. ALL DIMENSIONS AND ELEVATIONS (M.S.L.) ARE IN METERS, UNLESS OTHERWISE SHOWN.
2. SYMBOLS, ABBREVIATIONS AND GENERAL NOTES SEE DWG. NO. KLP-GN-03
3. THE ALIGNMENT OF THE HEADRACE AND RELATED STRUCTURES SHALL BE CHECK AND CORRECTED BY THE CONTRACTOR TO SUIT THE FIELD CONDITIONS AND SHALL BE SUBMITTED TO DEDE'S FIELD ENGINEER FOR APPROVAL


REFERENCE DRAWINGS :

1. HEADRACE PLAN AND PROFILE, STA. 0+000 TO STA. 0+500 KLP-HR-03
2. HEADRACE DRAIN CULVERT DETAILS OF REINFORCEMENT KLP-HR-21
3. HEADRACE TYPICAL SECTIONS AND DETAIL KLP-HR-08

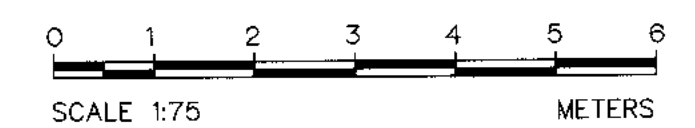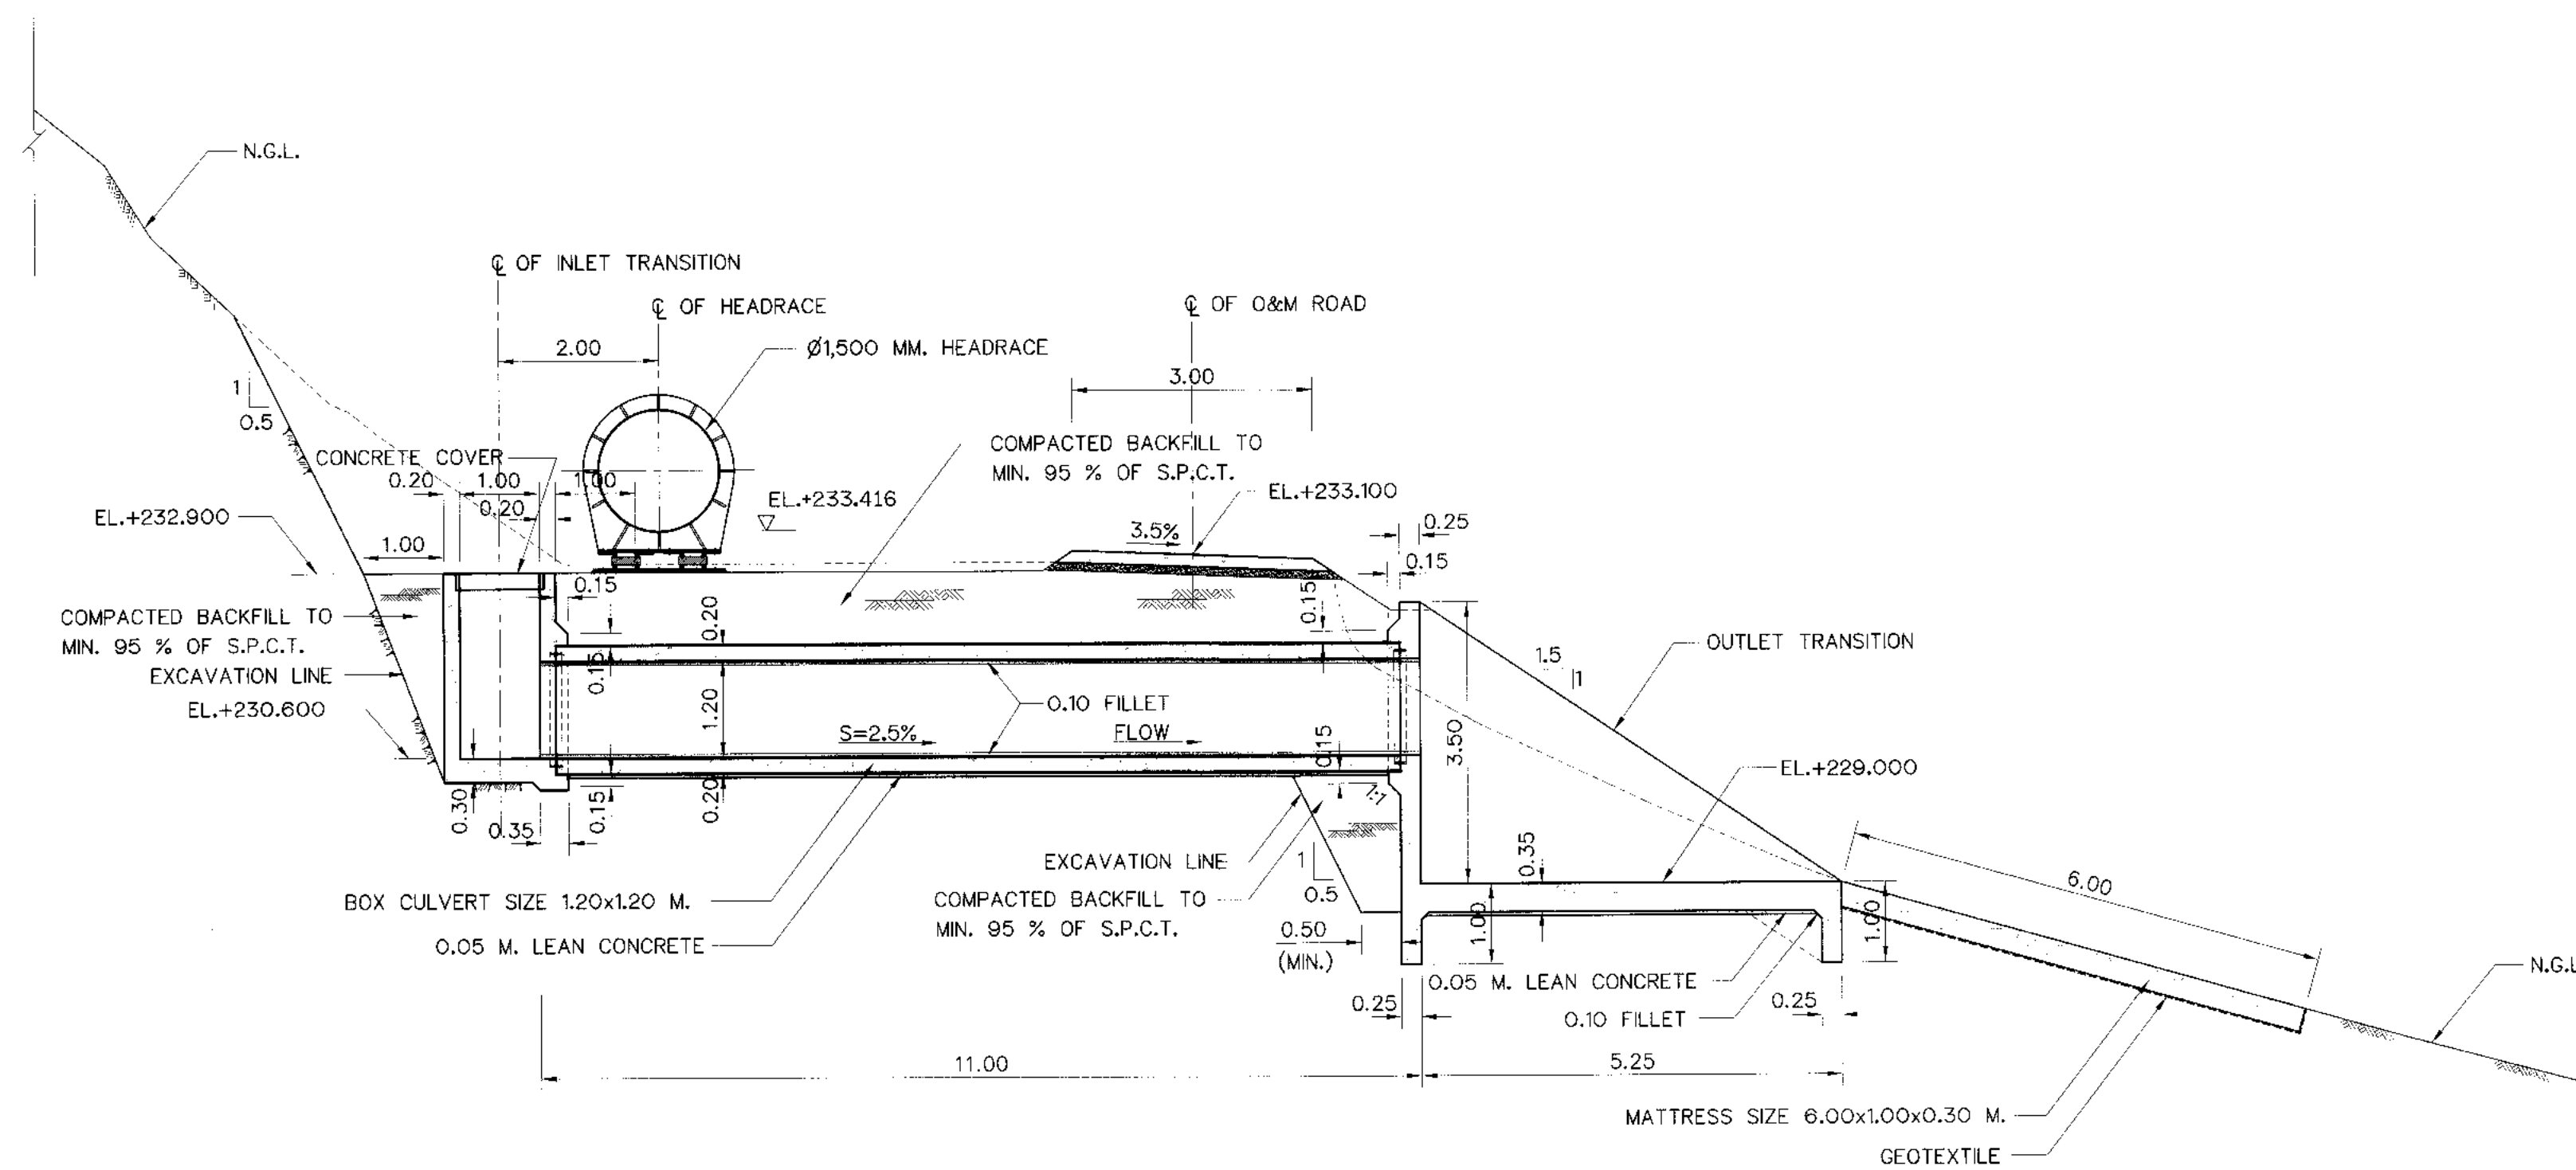

KINGDOM OF THAILAND Department of Alternative Energy Development and Efficiency MINISTRY OF ENERGY	
KLONG LAM PLOK HYDROPOWER PROJECT	
CIVIL WORKS AND TRANSMISSION LINE HEADRACE DRAIN CULVERT STA. 0+191.773 , PLAN AND SECTION	
P&C MANAGEMENT CO.,LTD. DESIGNED <i>[Signature]</i> 08/03/2559 08.6226 DRAWN <i>[Signature]</i> CHECKED <i>[Signature]</i> 08/03/2559 08.6226 PROJECT MANAGER	MINISTRY OF ENERGY REVIEWED <i>[Signature]</i> SUBMITTED <i>[Signature]</i> RECOMMENDED <i>[Signature]</i> APPROVED <i>[Signature]</i> DRAWING NO. KLP-HR-14 SHEET NO. 37 OF 110

3				
2				
1				
NO.	DATE	REVISIONS	CHECKED	APPROVED

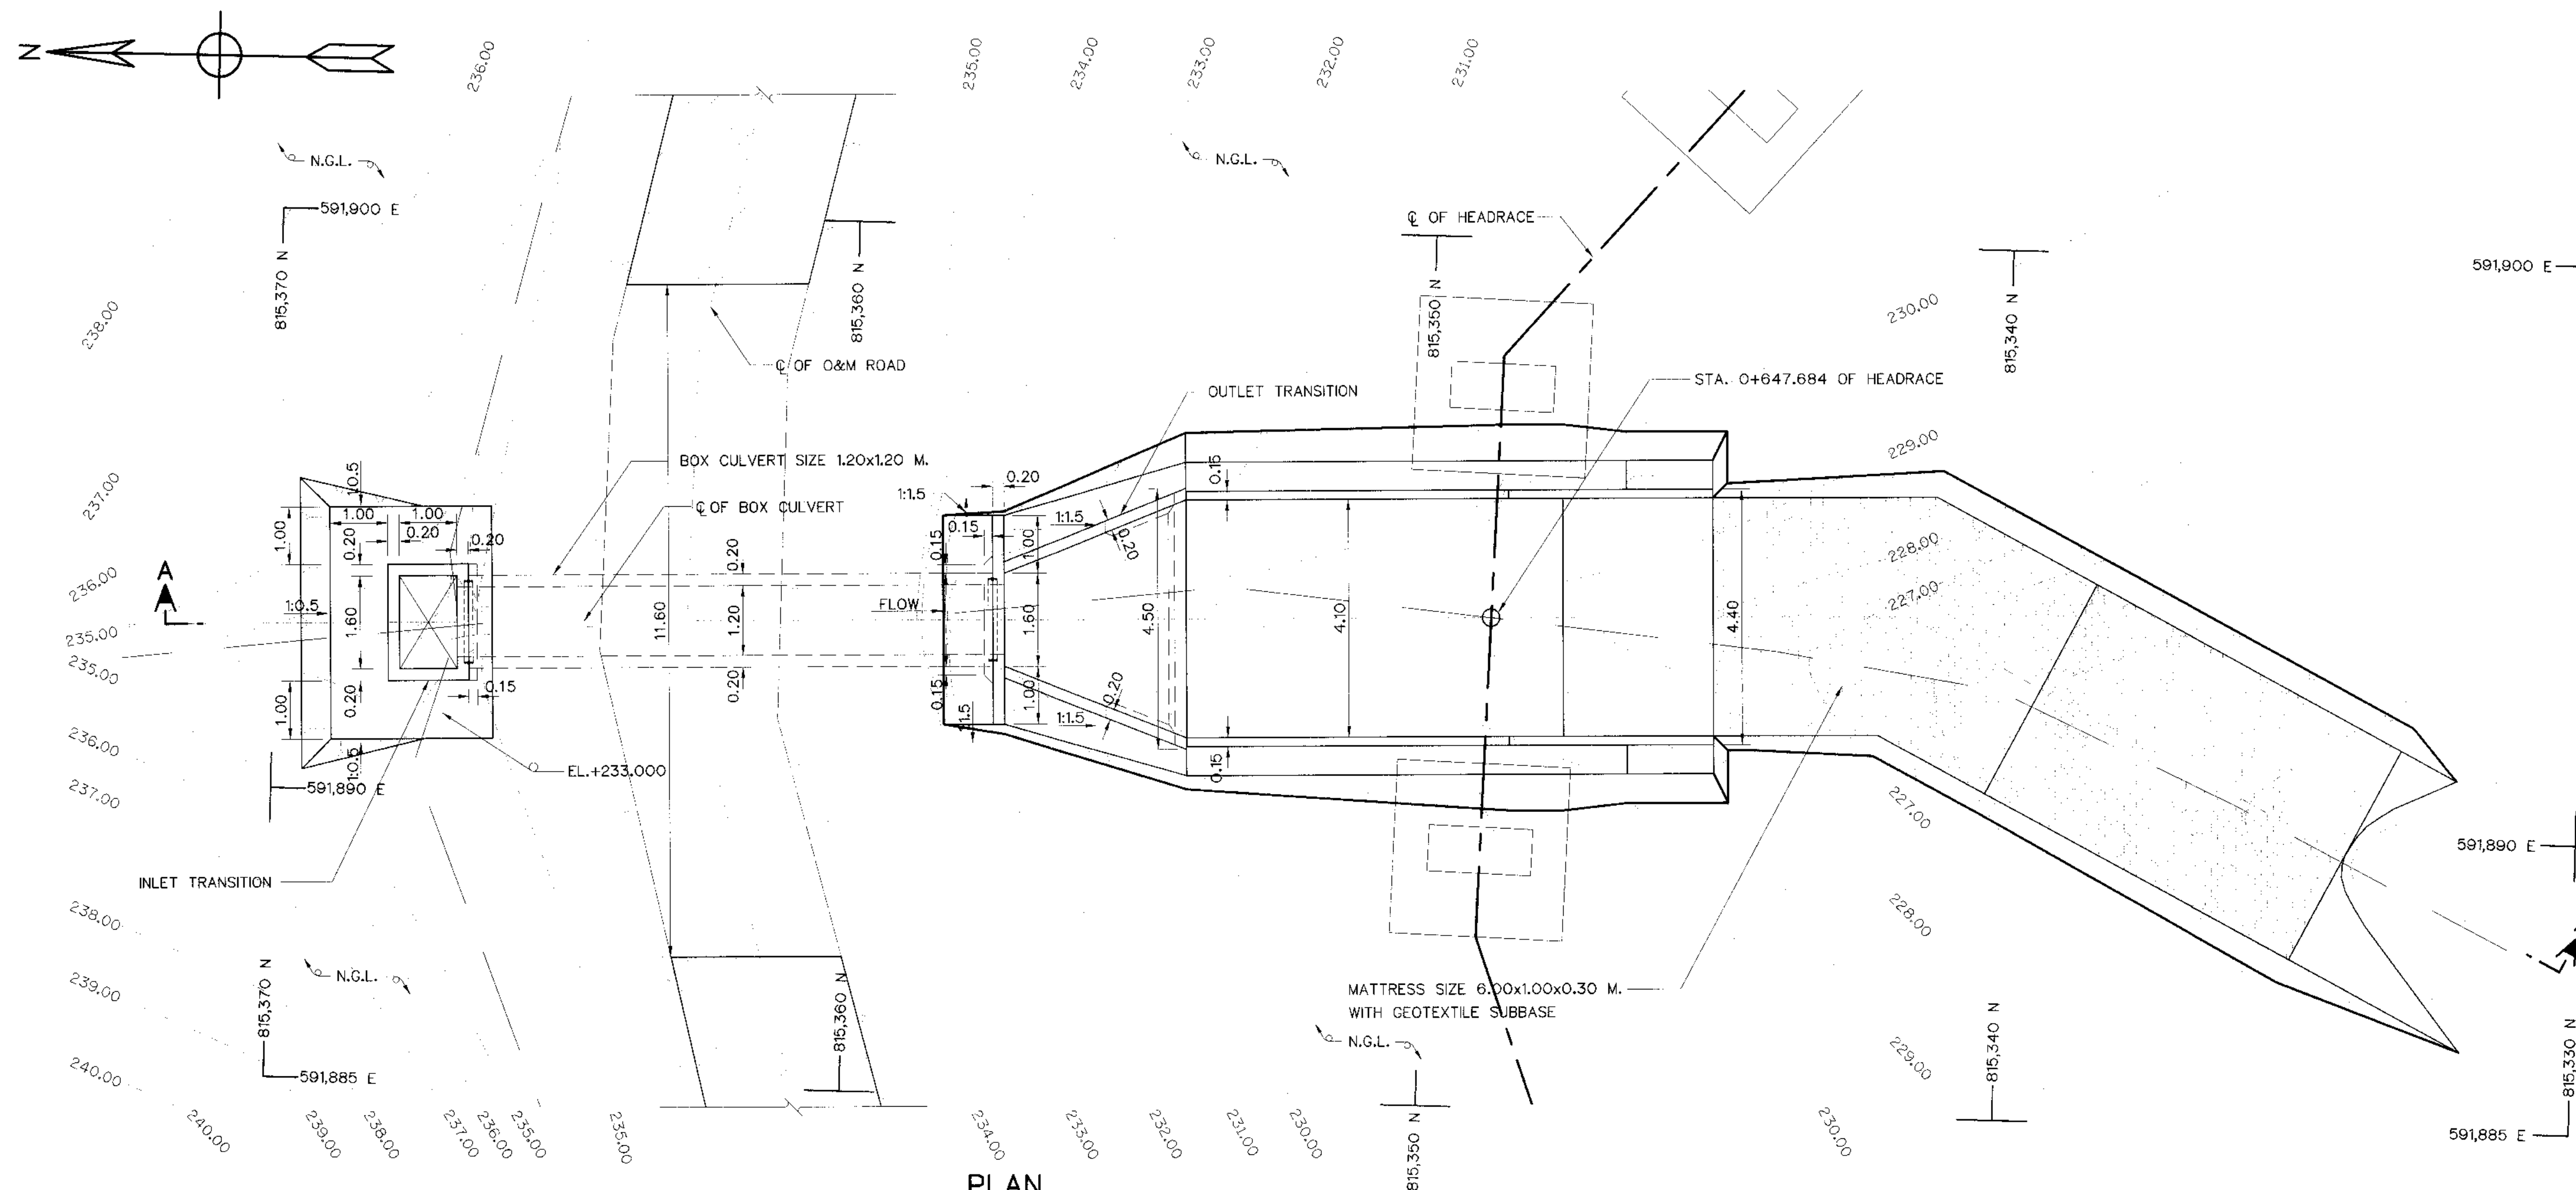


PLAN
SCALE 1:75

NOTES :


1. ALL DIMENSIONS AND ELEVATIONS (M.S.L.) ARE IN METERS. UNLESS OTHERWISE SHOWN.
2. SYMBOLS, ABBREVIATIONS AND GENERAL NOTES SEE DWG. NO. KLP-GN-03
3. THE ALIGNMENT OF THE HEADRACE AND RELATED STRUCTURES SHALL BE CHECK AND CORRECTED BY THE CONTRACTOR TO SUIT THE FIELD CONDITIONS AND SHALL BE SUBMITTED TO DEDE'S FIELD ENGINEER FOR APPROVAL

REFERENCE DRAWINGS :

1. HEADRACE PLAN AND PROFILE, STA. 0+500 TO STA. 1+000 KLP-HR-04
2. HEADRACE DRAIN CULVERT DETAILS OF REINFORCEMENT KLP-HR-21
3. HEADRACE TYPICAL SECTIONS AND DETAIL KLP-HR-06

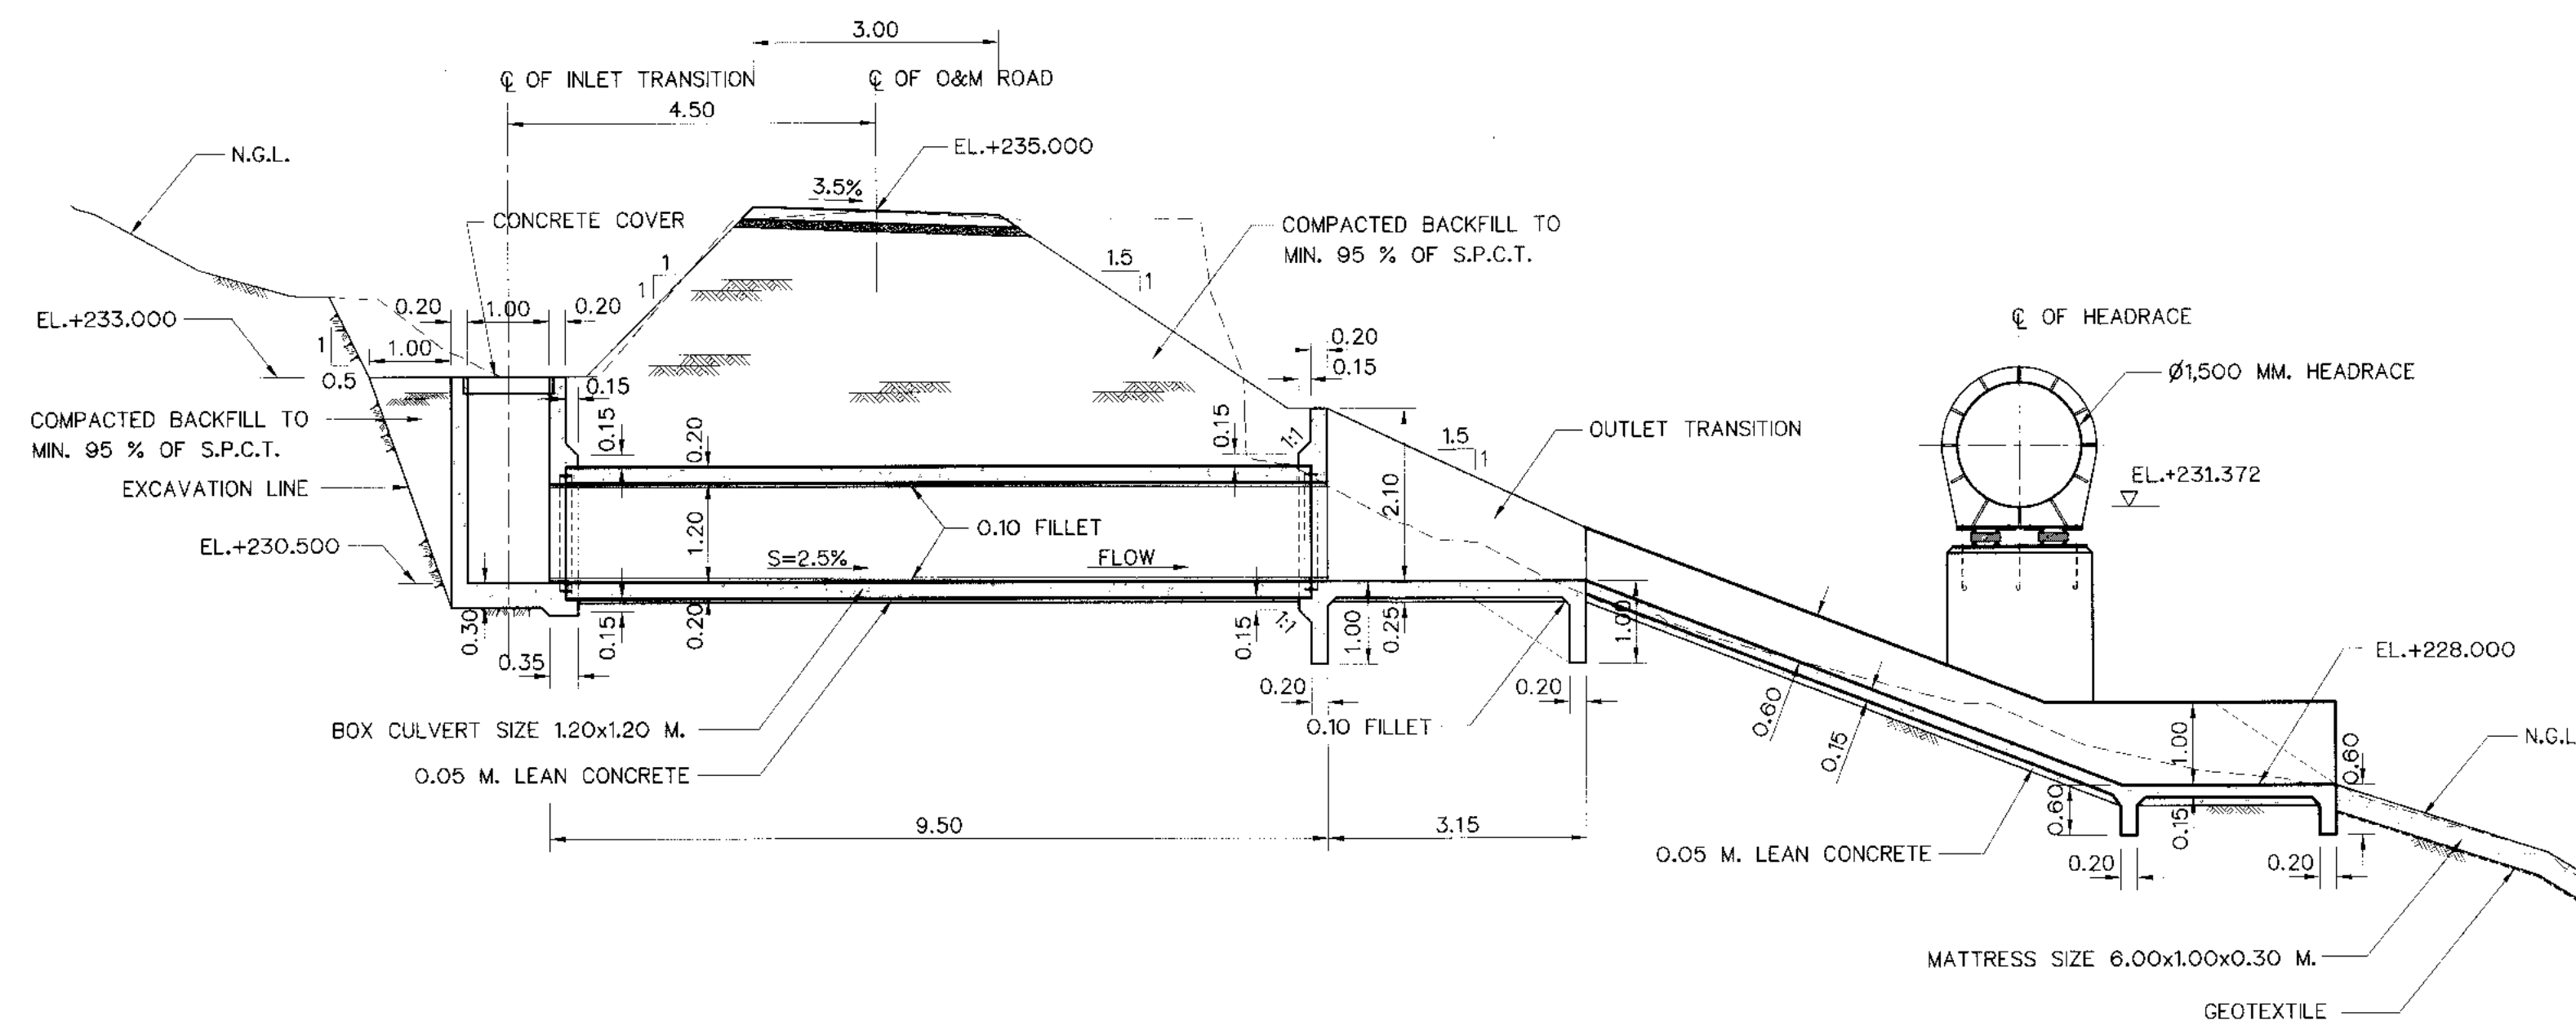


SECTION A-A
SCALE 1:75

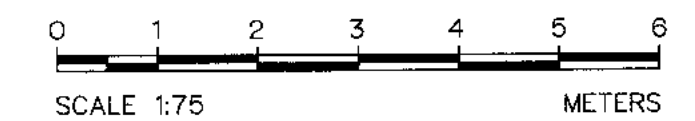

KINGDOM OF THAILAND Department of Alternative Energy Development and Efficiency MINISTRY OF ENERGY	
KLONG LAM PLOK HYDROPOWER PROJECT	
CIVIL WORKS AND TRANSMISSION LINE HEADRACE DRAIN CULVERT STA. 0+647.684 , PLAN AND SECTION	
DESIGNED P&C MANAGEMENT CO., LTD. NO. 28/29074 DATE 08/03/2559	REVIEWED SUBMITTED RECOMMENDED APPROVED
PROJECT MANAGER	SHEET NO. 39 OF 110

NO.	DATE	REVISIONS	CHECKED	APPROVED
3				
2				
1				
CONSULTANTS			DEDE	


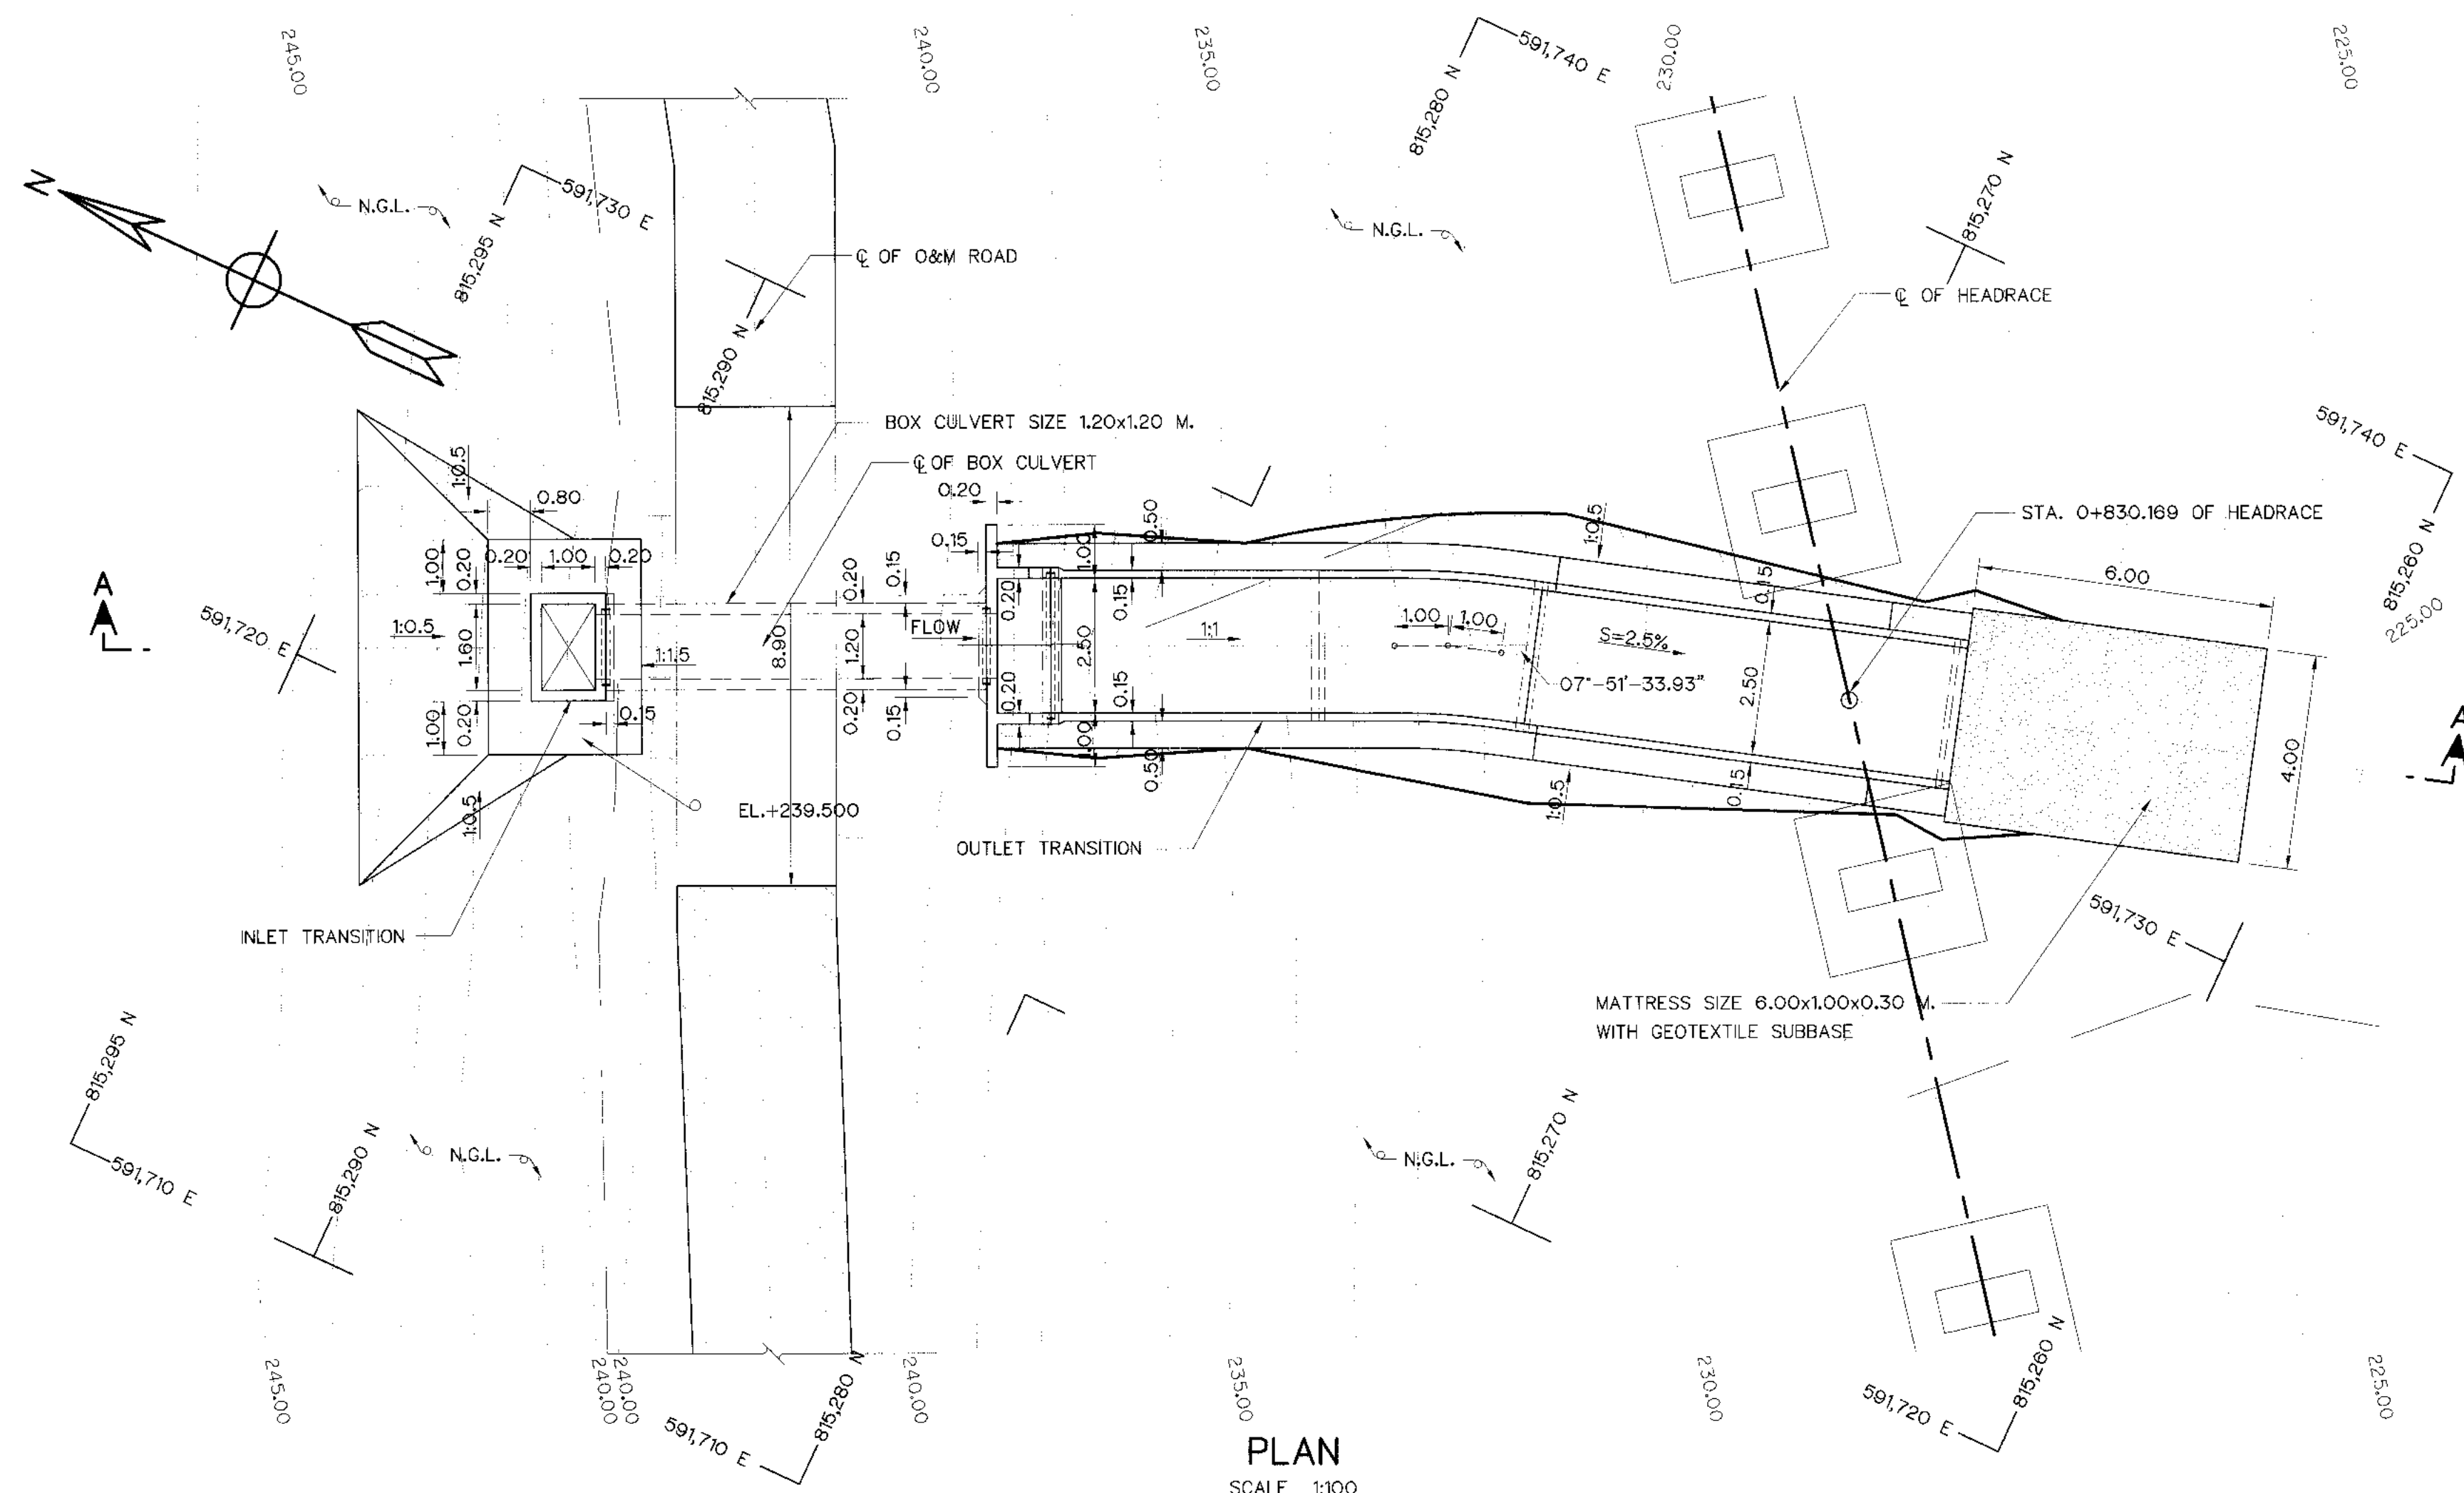


NOTES :



1. ALL DIMENSIONS AND ELEVATIONS (M.S.L.) ARE IN METERS, UNLESS OTHERWISE SHOWN.
2. SYMBOLS, ABBREVIATIONS AND GENERAL NOTES SEE DWG. NO. KLP-GN-03
3. THE ALIGNMENT OF THE HEADRACE AND RELATED STRUCTURES SHALL BE CHECK AND CORRECTED BY THE CONTRACTOR TO SUIT THE FIELD CONDITIONS AND SHALL BE SUBMITTED TO DEDE'S FIELD ENGINEER FOR APPROVAL

REFERENCE DRAWINGS :

1. HEADRACE PLAN AND PROFILE, STA. 0+500 TO STA. 1+000 KLP-HR-04
2. HEADRACE DRAIN CULVERT DETAILS OF REINFORCEMENT KLP-HR-21
3. HEADRACE TYPICAL SECTIONS AND DETAIL KLP-HR-06

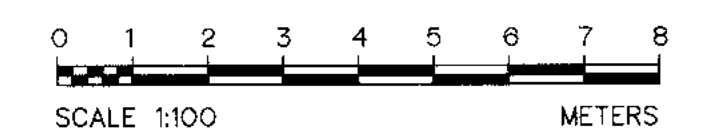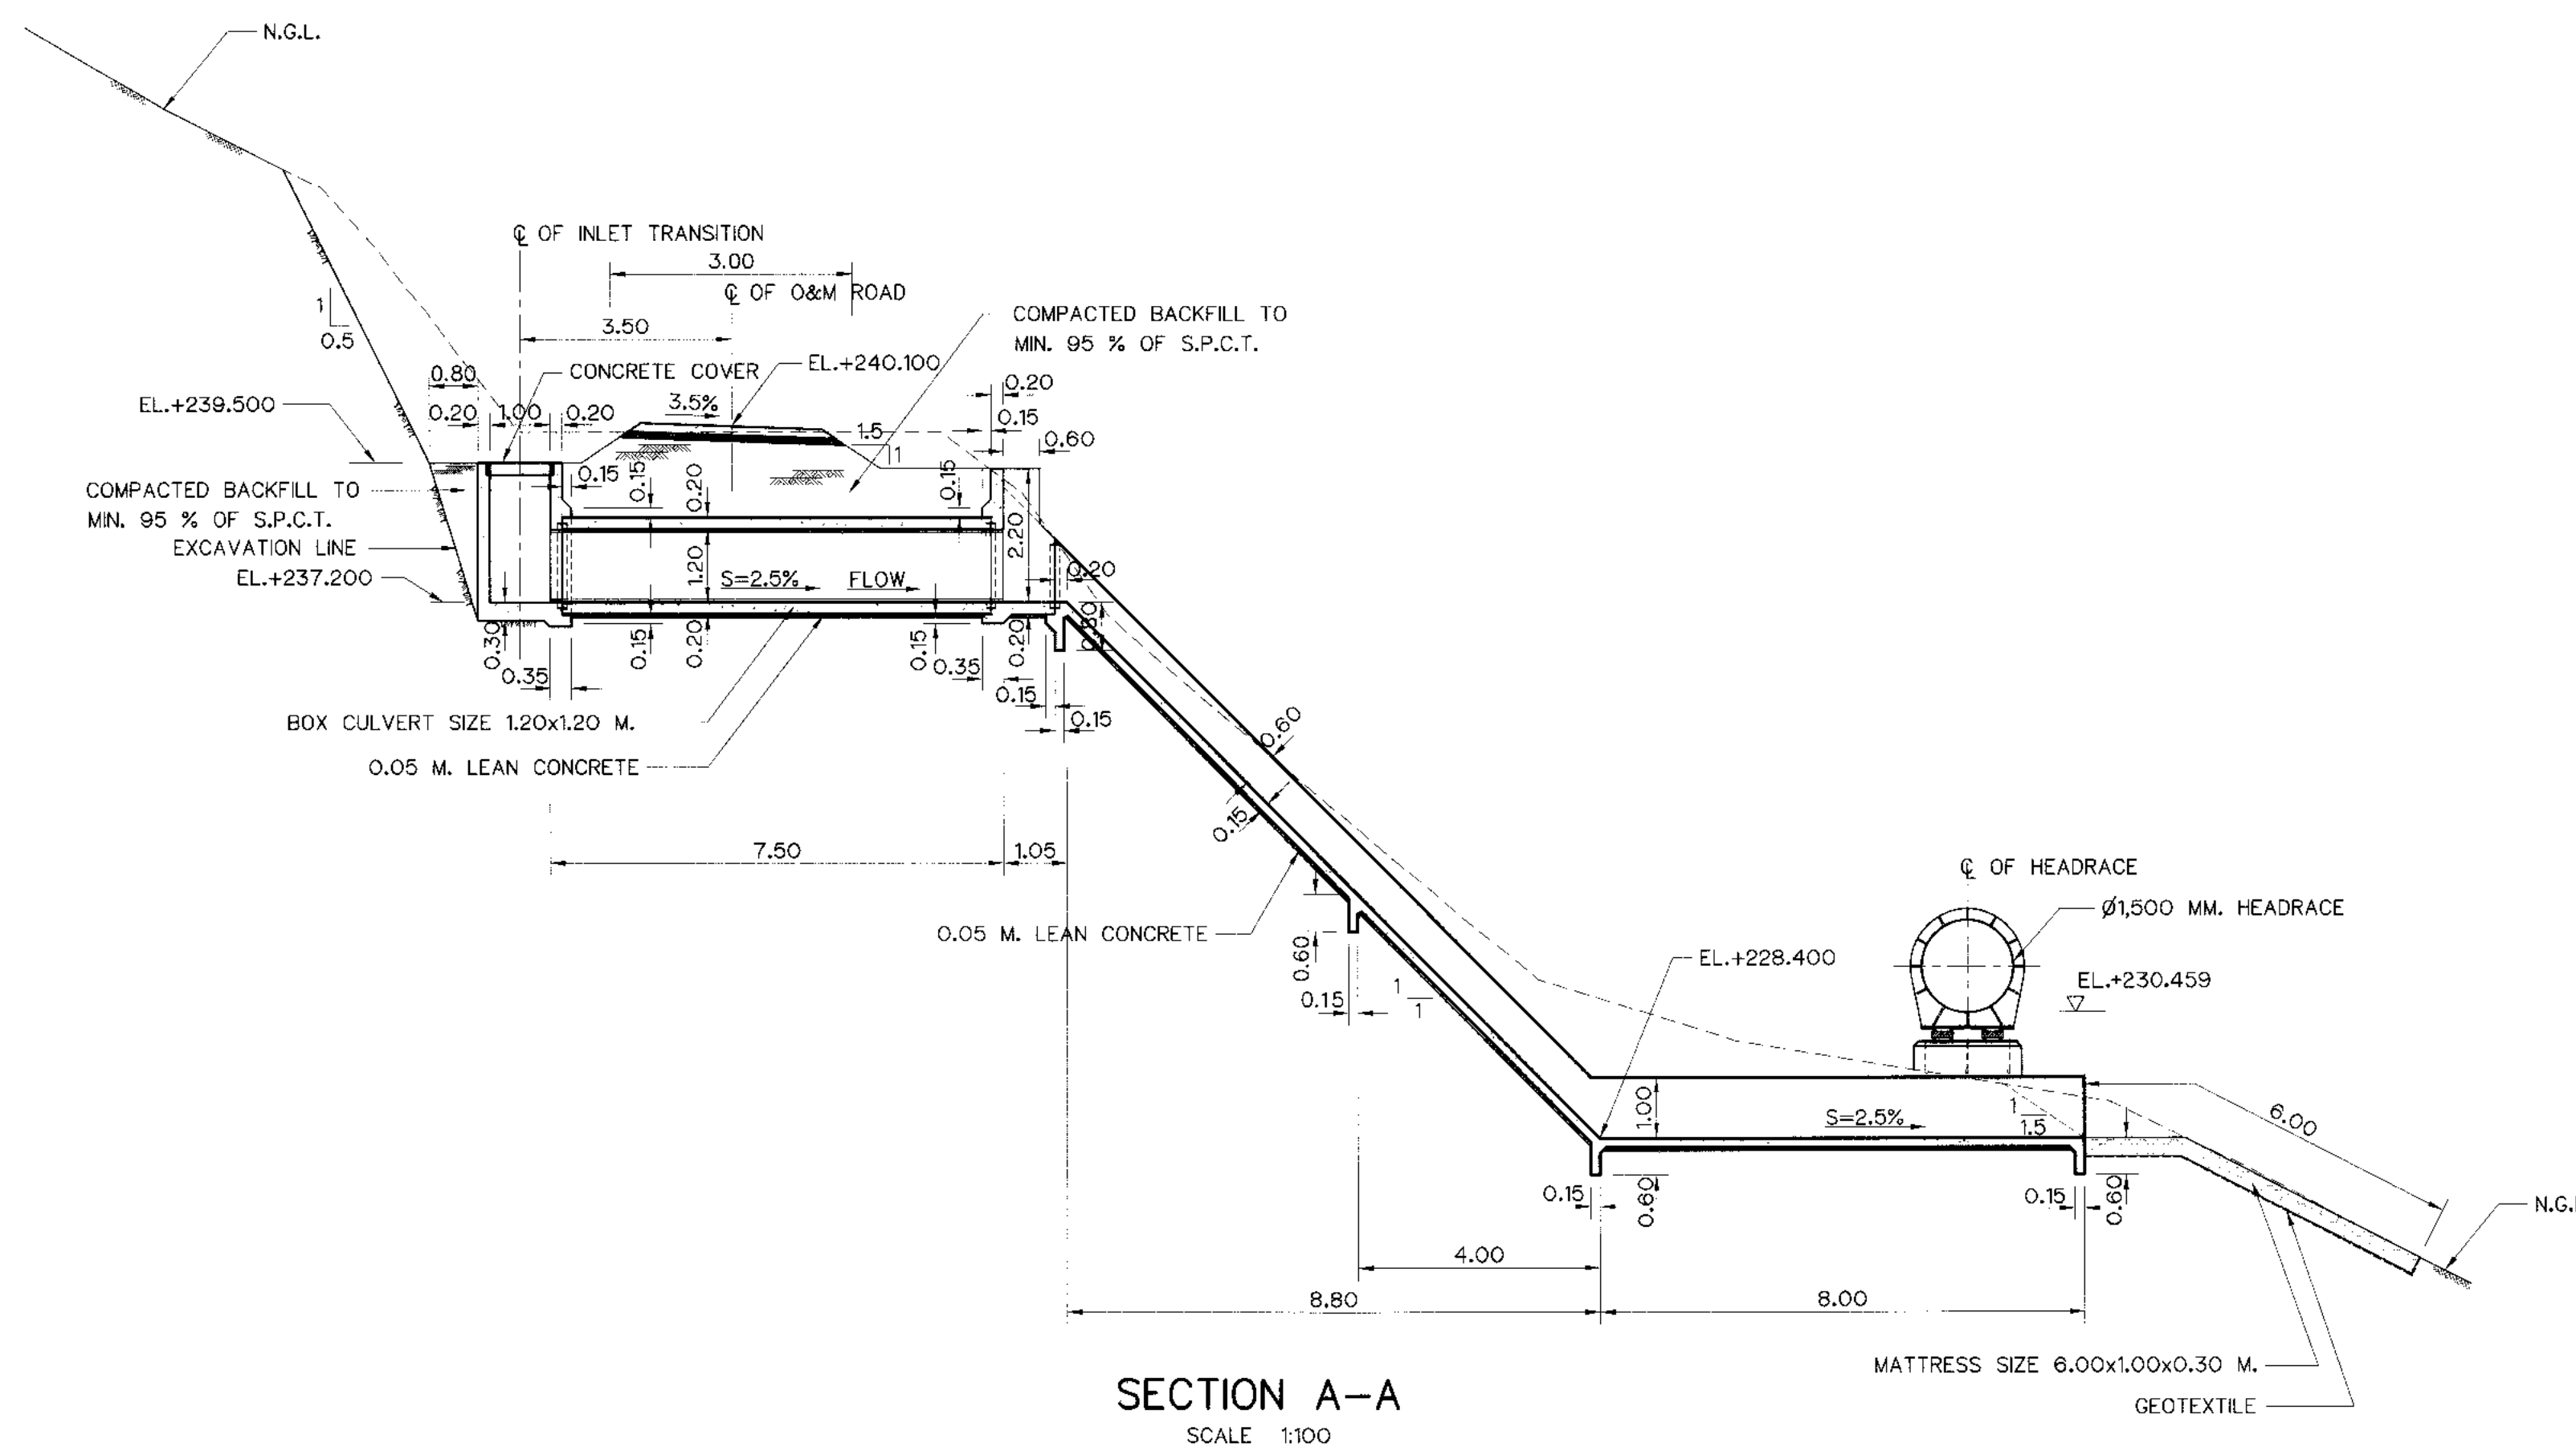

KINGDOM OF THAILAND Department of Alternative Energy Development and Efficiency MINISTRY OF ENERGY	
KLONG LAM PLOK HYDROPOWER PROJECT	
CIVIL WORKS AND TRANSMISSION LINE HEADRACE DRAIN CULVERT STA. 0+830.169 , PLAN AND SECTION	
DESIGNED NO. 18.29074 DATE 28.6.226	REVIEWED SUBMITTED RECOMMENDED APPROVED P. Harnodh
DRAWN NO. 18.29074 DATE 28.6.226	CHECKED NO. 18.29074 DATE 28.6.226
CONSULTANTS DEDE	PROJECT MANAGER DATE 08/03/2559
DRAWING NO. KLP-HR-17	SHEET NO. 40 OF 110

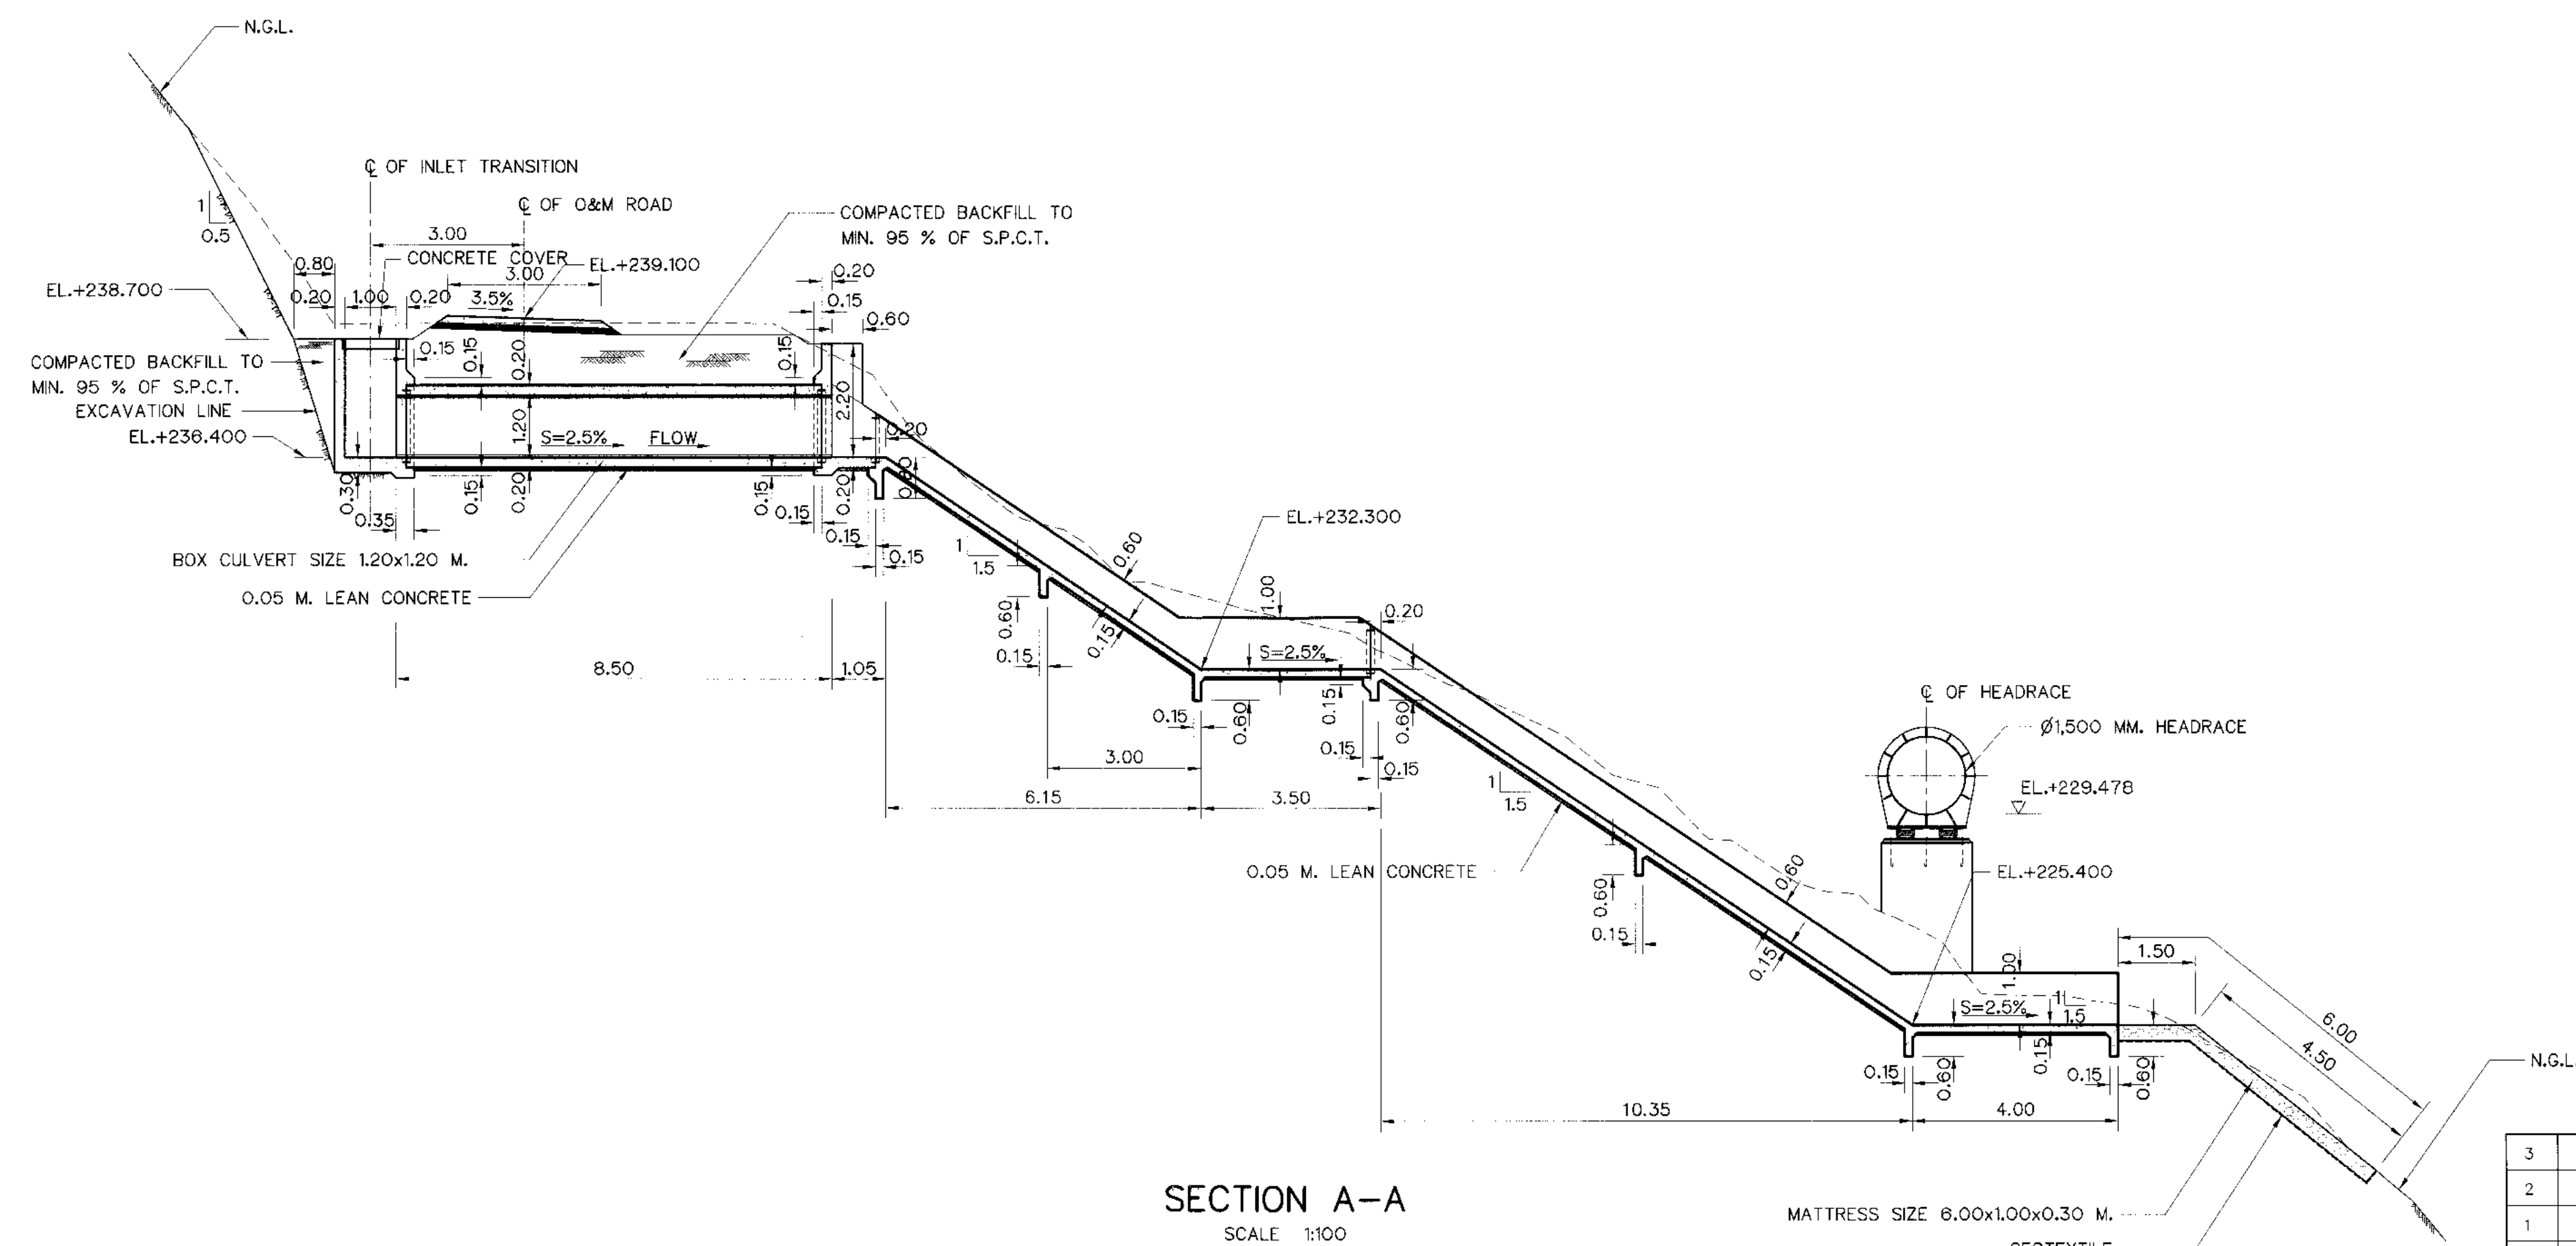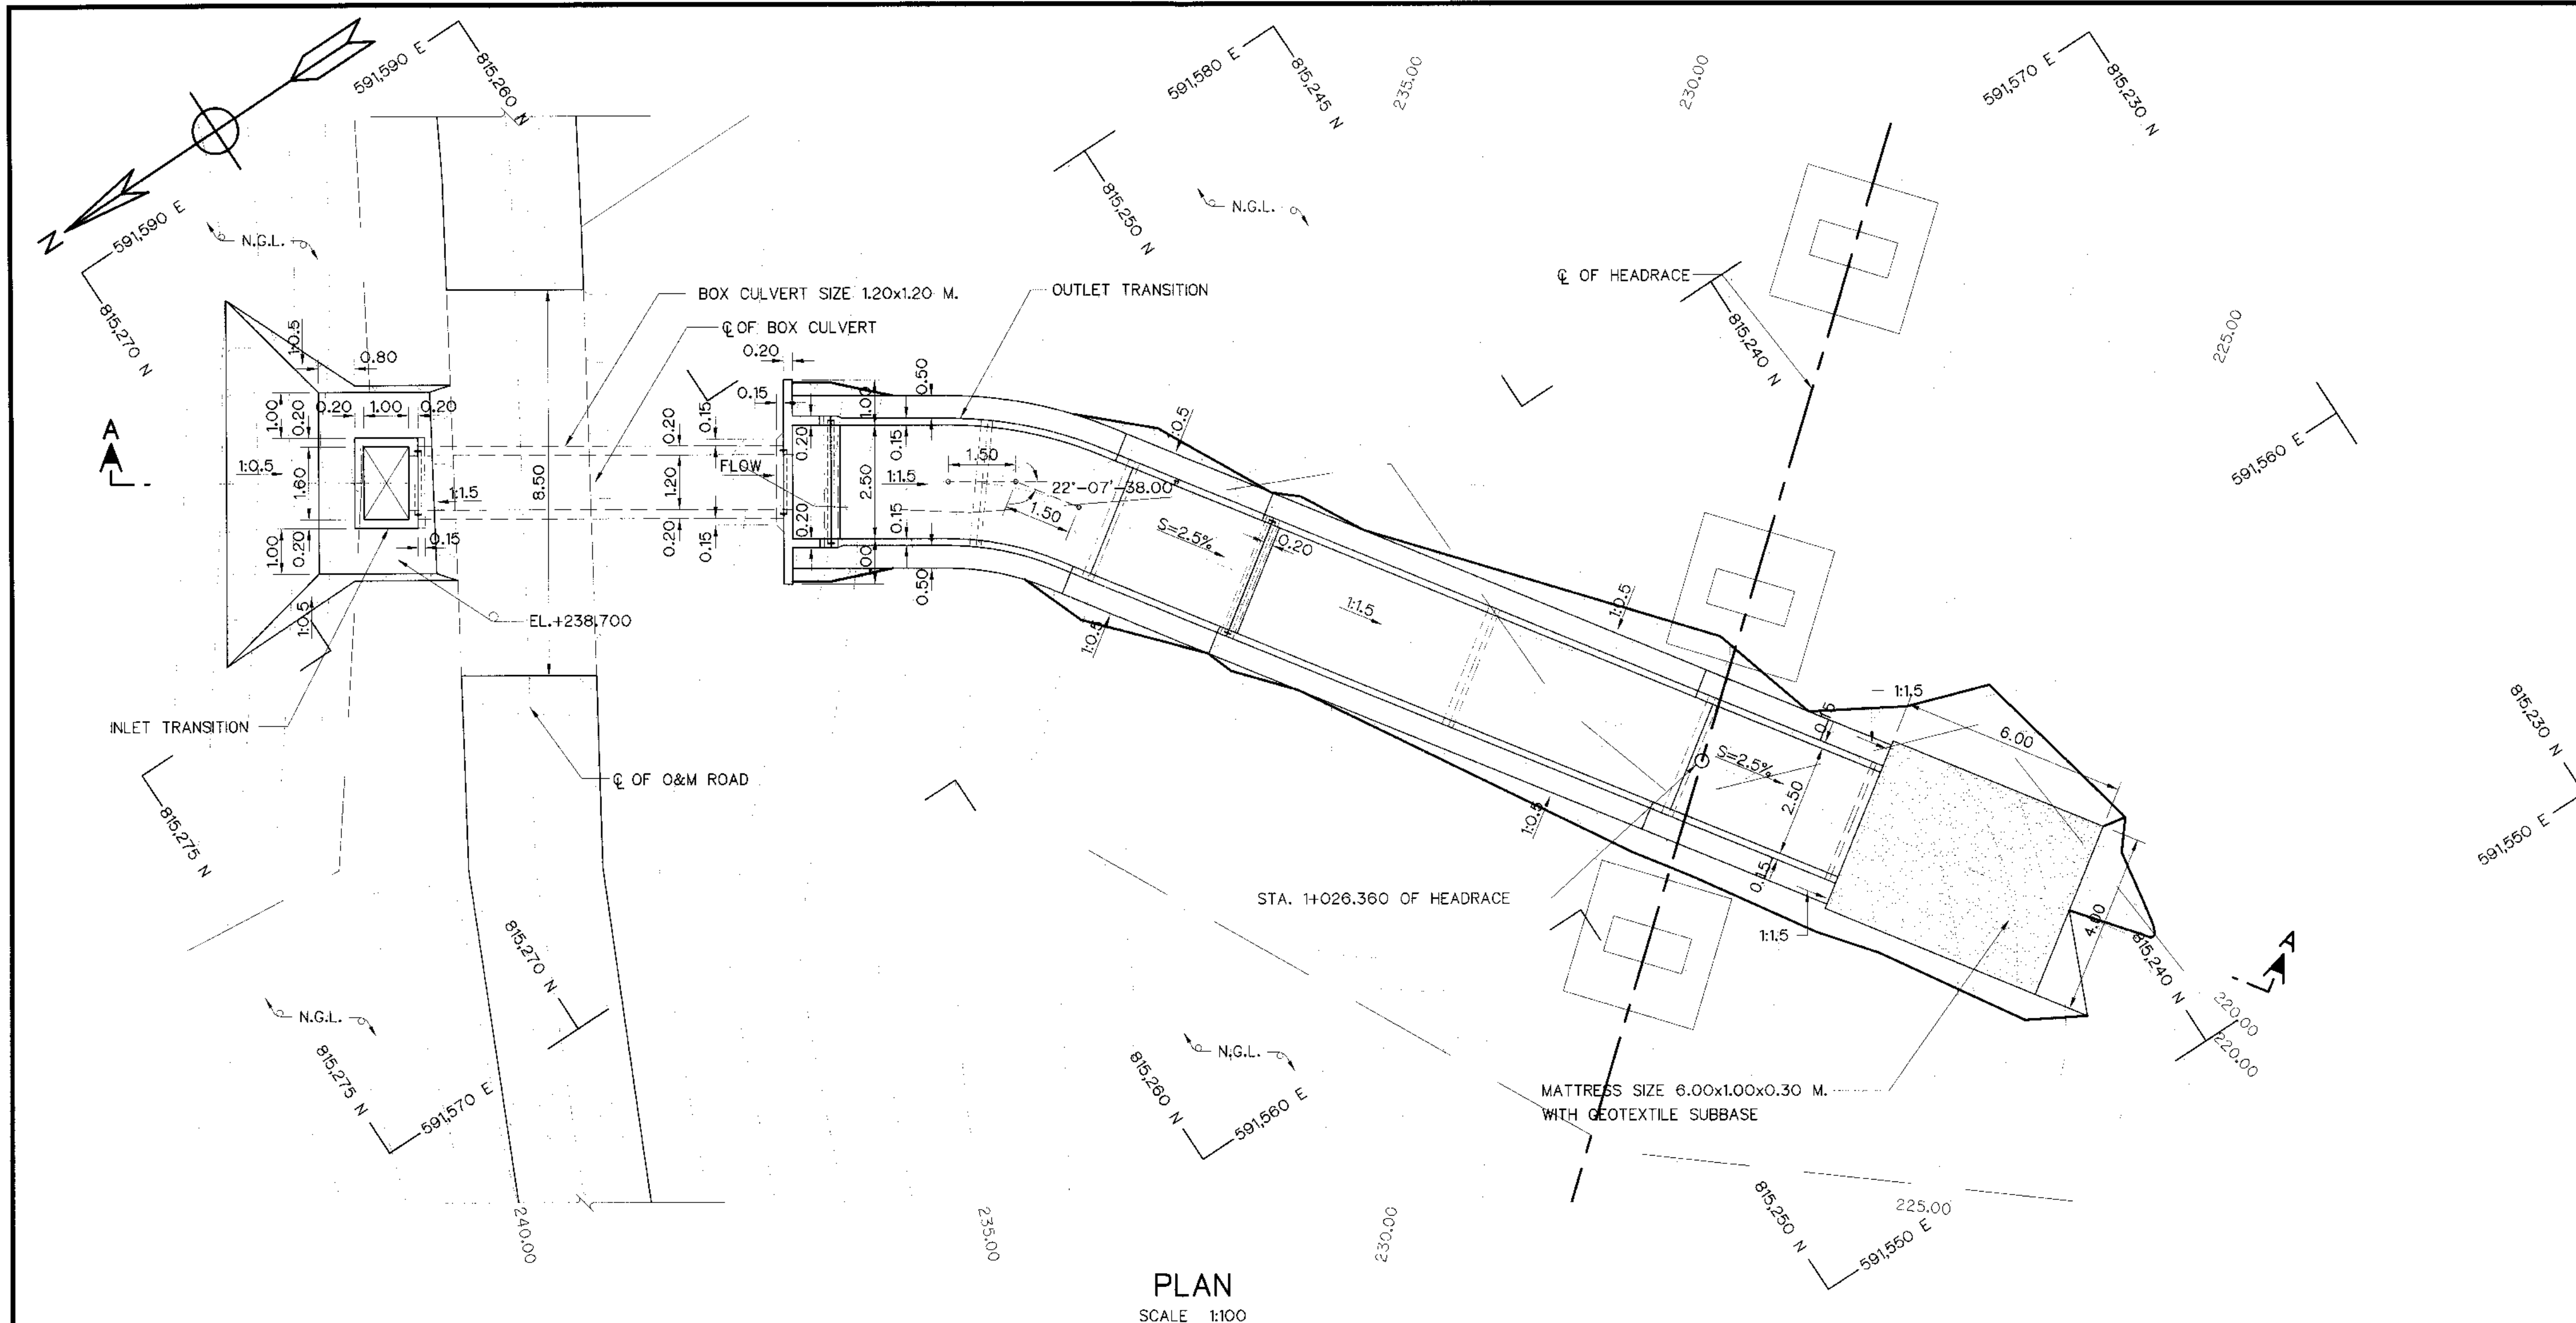


NOTES :



1. ALL DIMENSIONS AND ELEVATIONS (M.S.L.) ARE IN METERS, UNLESS OTHERWISE SHOWN.
2. SYMBOLS, ABBREVIATIONS AND GENERAL NOTES SEE DWG. NO. KLP-GN-03
3. THE ALIGNMENT OF THE HEADRACE AND RELATED STRUCTURES SHALL BE CHECK AND CORRECTED BY THE CONTRACTOR TO SUIT THE FIELD CONDITIONS AND SHALL BE SUBMITTED TO DEDE'S FIELD ENGINEER FOR APPROVAL

REFERENCE DRAWINGS :

1. HEADRACE PLAN AND PROFILE, STA. 1+000 TO STA. 1+459.506 KLP-HR-05
2. HEADRACE DRAIN CULVERT DETAILS OF REINFORCEMENT KLP-HR-21
3. HEADRACE TYPICAL SECTIONS AND DETAIL KLP-HR-06

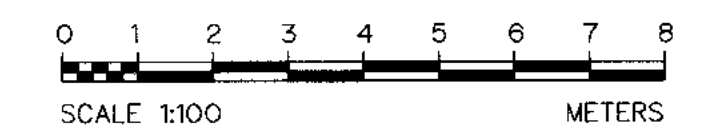

KINGDOM OF THAILAND Department of Alternative Energy Development and Efficiency MINISTRY OF ENERGY	
KLONG LAM PLOK HYDROPOWER PROJECT	
CIVIL WORKS AND TRANSMISSION LINE HEADRACE DRAIN CULVERT STA. 1+026.360 , PLAN AND SECTION	
P&C MANAGEMENT CO.,LTD.	REVIEWED
DESIGNED	SUBMITTED
DRAWN	RECOMMENDED
CHECKED	APPROVED
PROJECT MANAGER	DATE
CONSULTANTS	DEDE
DRAWING NO. KLP-HR-18	SHEET NO. 41 OF 110

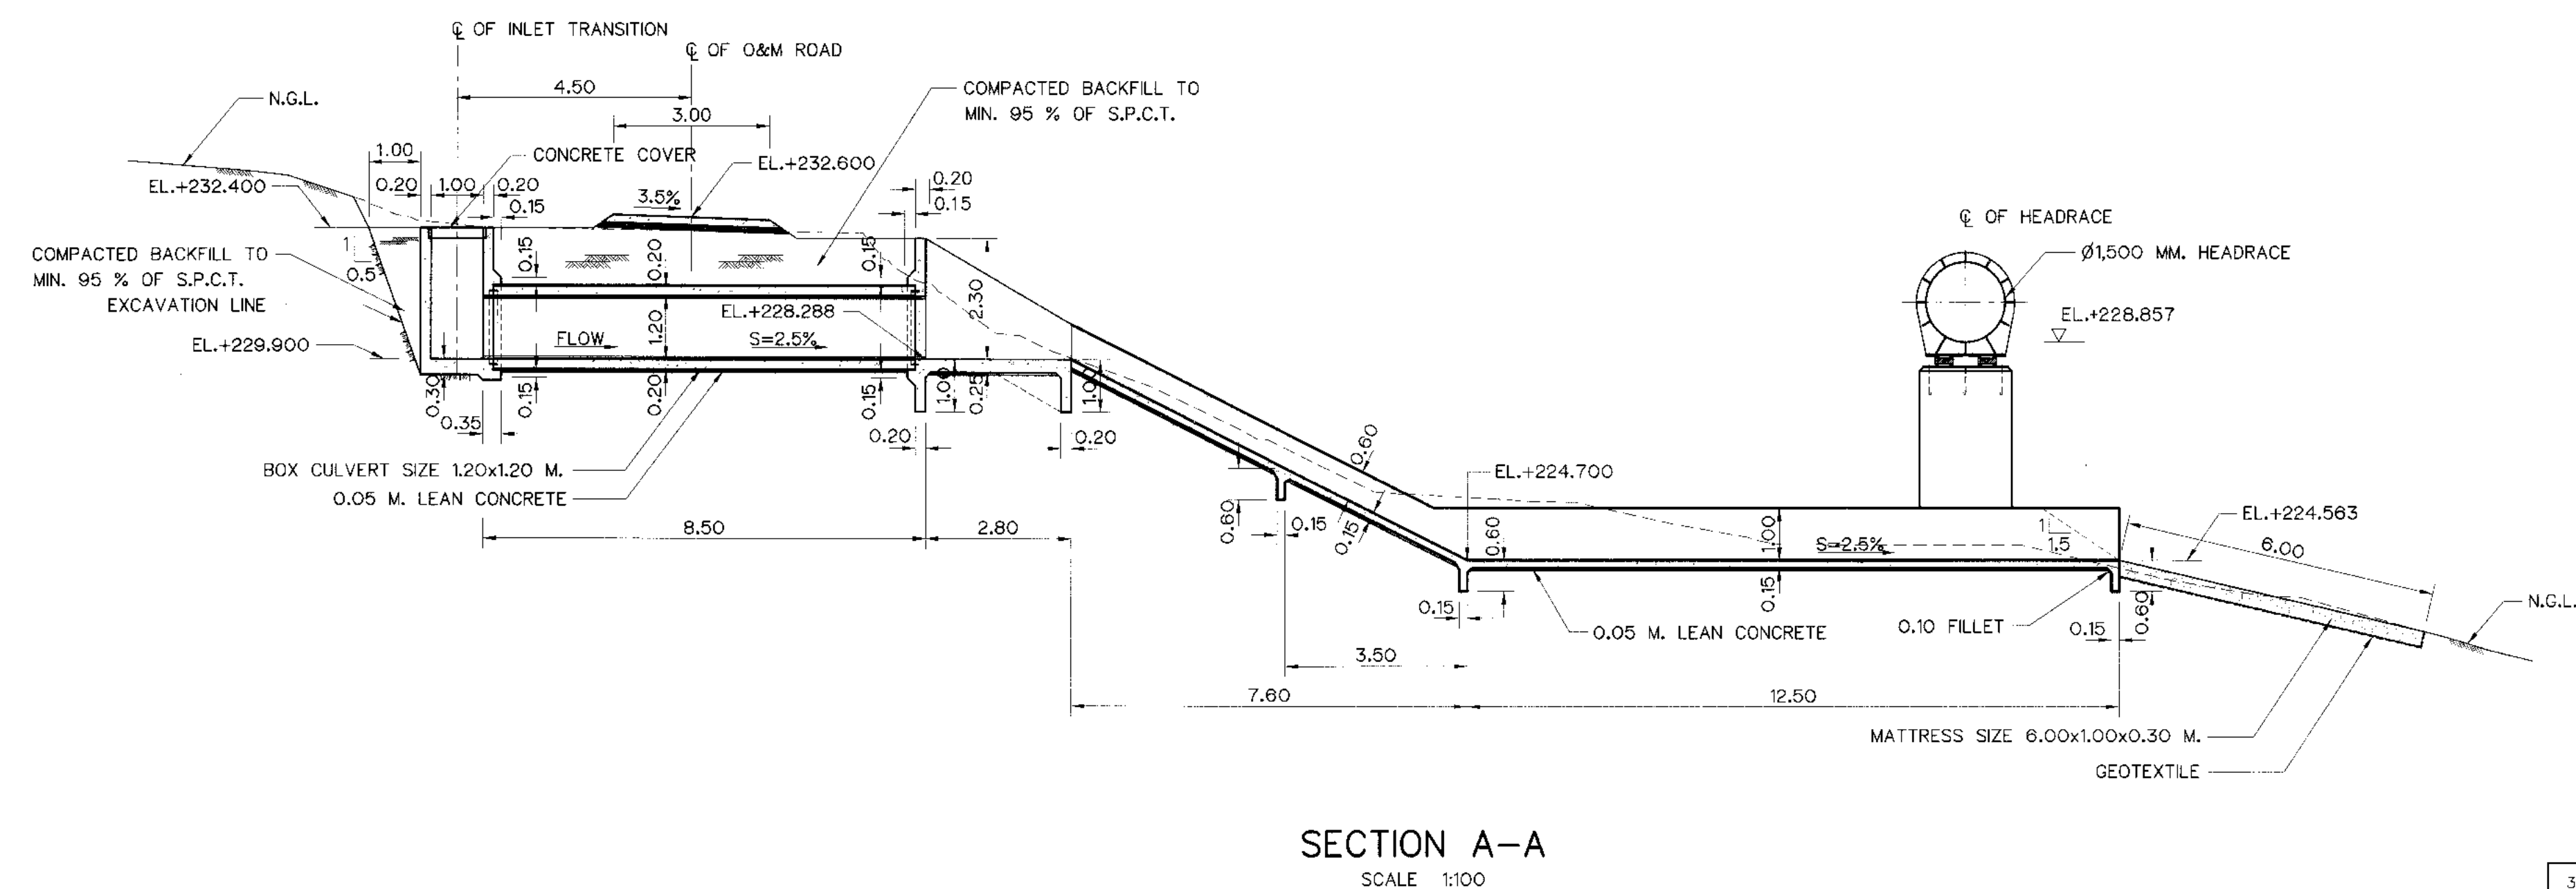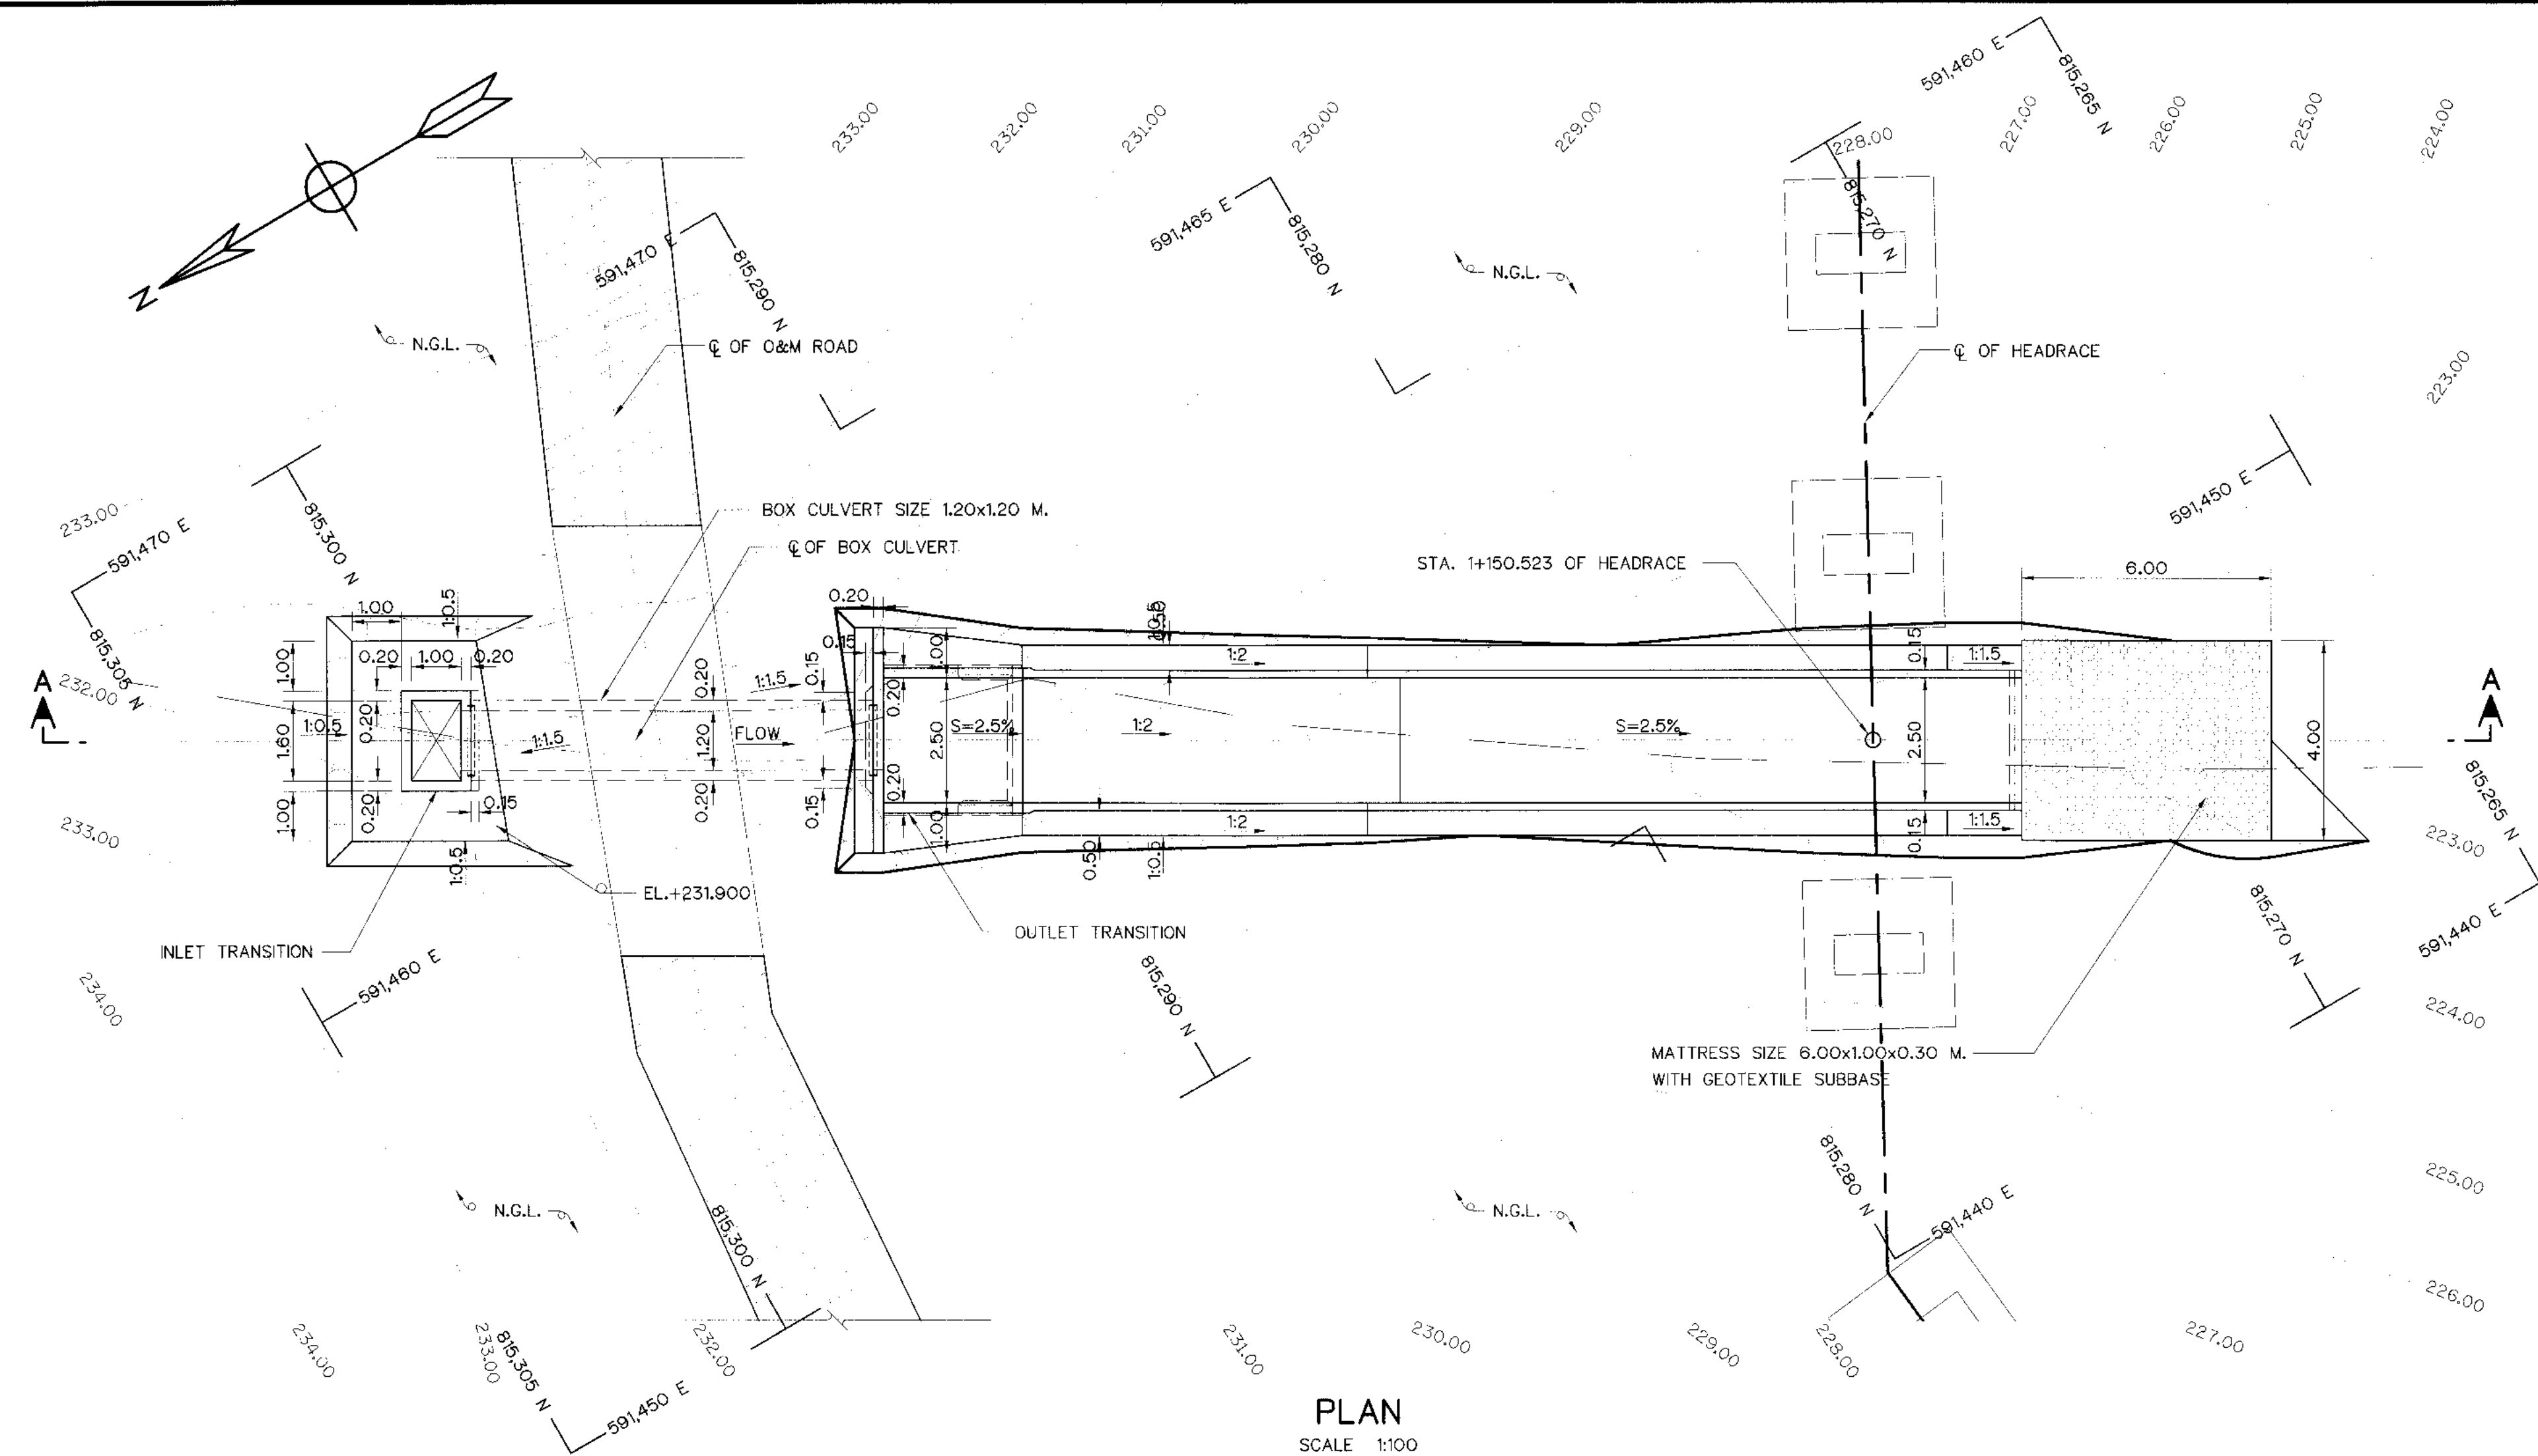


NOTES :


1. ALL DIMENSIONS AND ELEVATIONS (M.S.L.) ARE IN METERS, UNLESS OTHERWISE SHOWN.
2. SYMBOLS, ABBREVIATIONS AND GENERAL NOTES SEE DWG. NO. KLP-GN-03
3. THE ALIGNMENT OF THE HEADRACE AND RELATED STRUCTURES SHALL BE CHECK AND CORRECTED BY THE CONTRACTOR TO SUIT THE FIELD CONDITIONS AND SHALL BE SUBMITTED TO DEDE'S FIELD ENGINEER FOR APPROVAL

REFERENCE DRAWINGS :

1. HEADRACE PLAN AND PROFILE, STA. 1+000 TO STA. 1+450.506 KLP-HR-05
2. HEADRACE DRAIN CULVERT DETAILS OF REINFORCEMENT KLP-HR-21
3. HEADRACE TYPICAL SECTIONS AND DETAIL KLP-HR-06

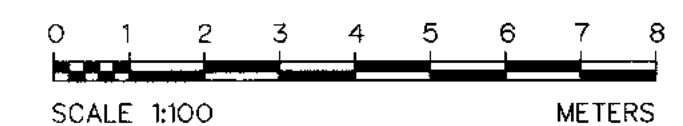


KINGDOM OF THAILAND Department of Alternative Energy Development and Efficiency MINISTRY OF ENERGY	
KLONG LAM PLOK HYDROPOWER PROJECT	
CIVIL WORKS AND TRANSMISSION LINE HEADRACE DRAIN CULVERT STA. 1+150.523 , PLAN AND SECTION	
DESIGNED <i>[Signature]</i> DRAWN <i>[Signature]</i> CHECKED <i>[Signature]</i> PROJECT MANAGER	REVIEWED <i>[Signature]</i> SUBMITTED <i>[Signature]</i> RECOMMENDED <i>[Signature]</i> APPROVED <i>[Signature]</i>
NO. DATE REVISIONS CHECKED APPROVED CONSULTANTS DEDE	DATE 08/03/2559 KLP-HR-19 42 OF 110

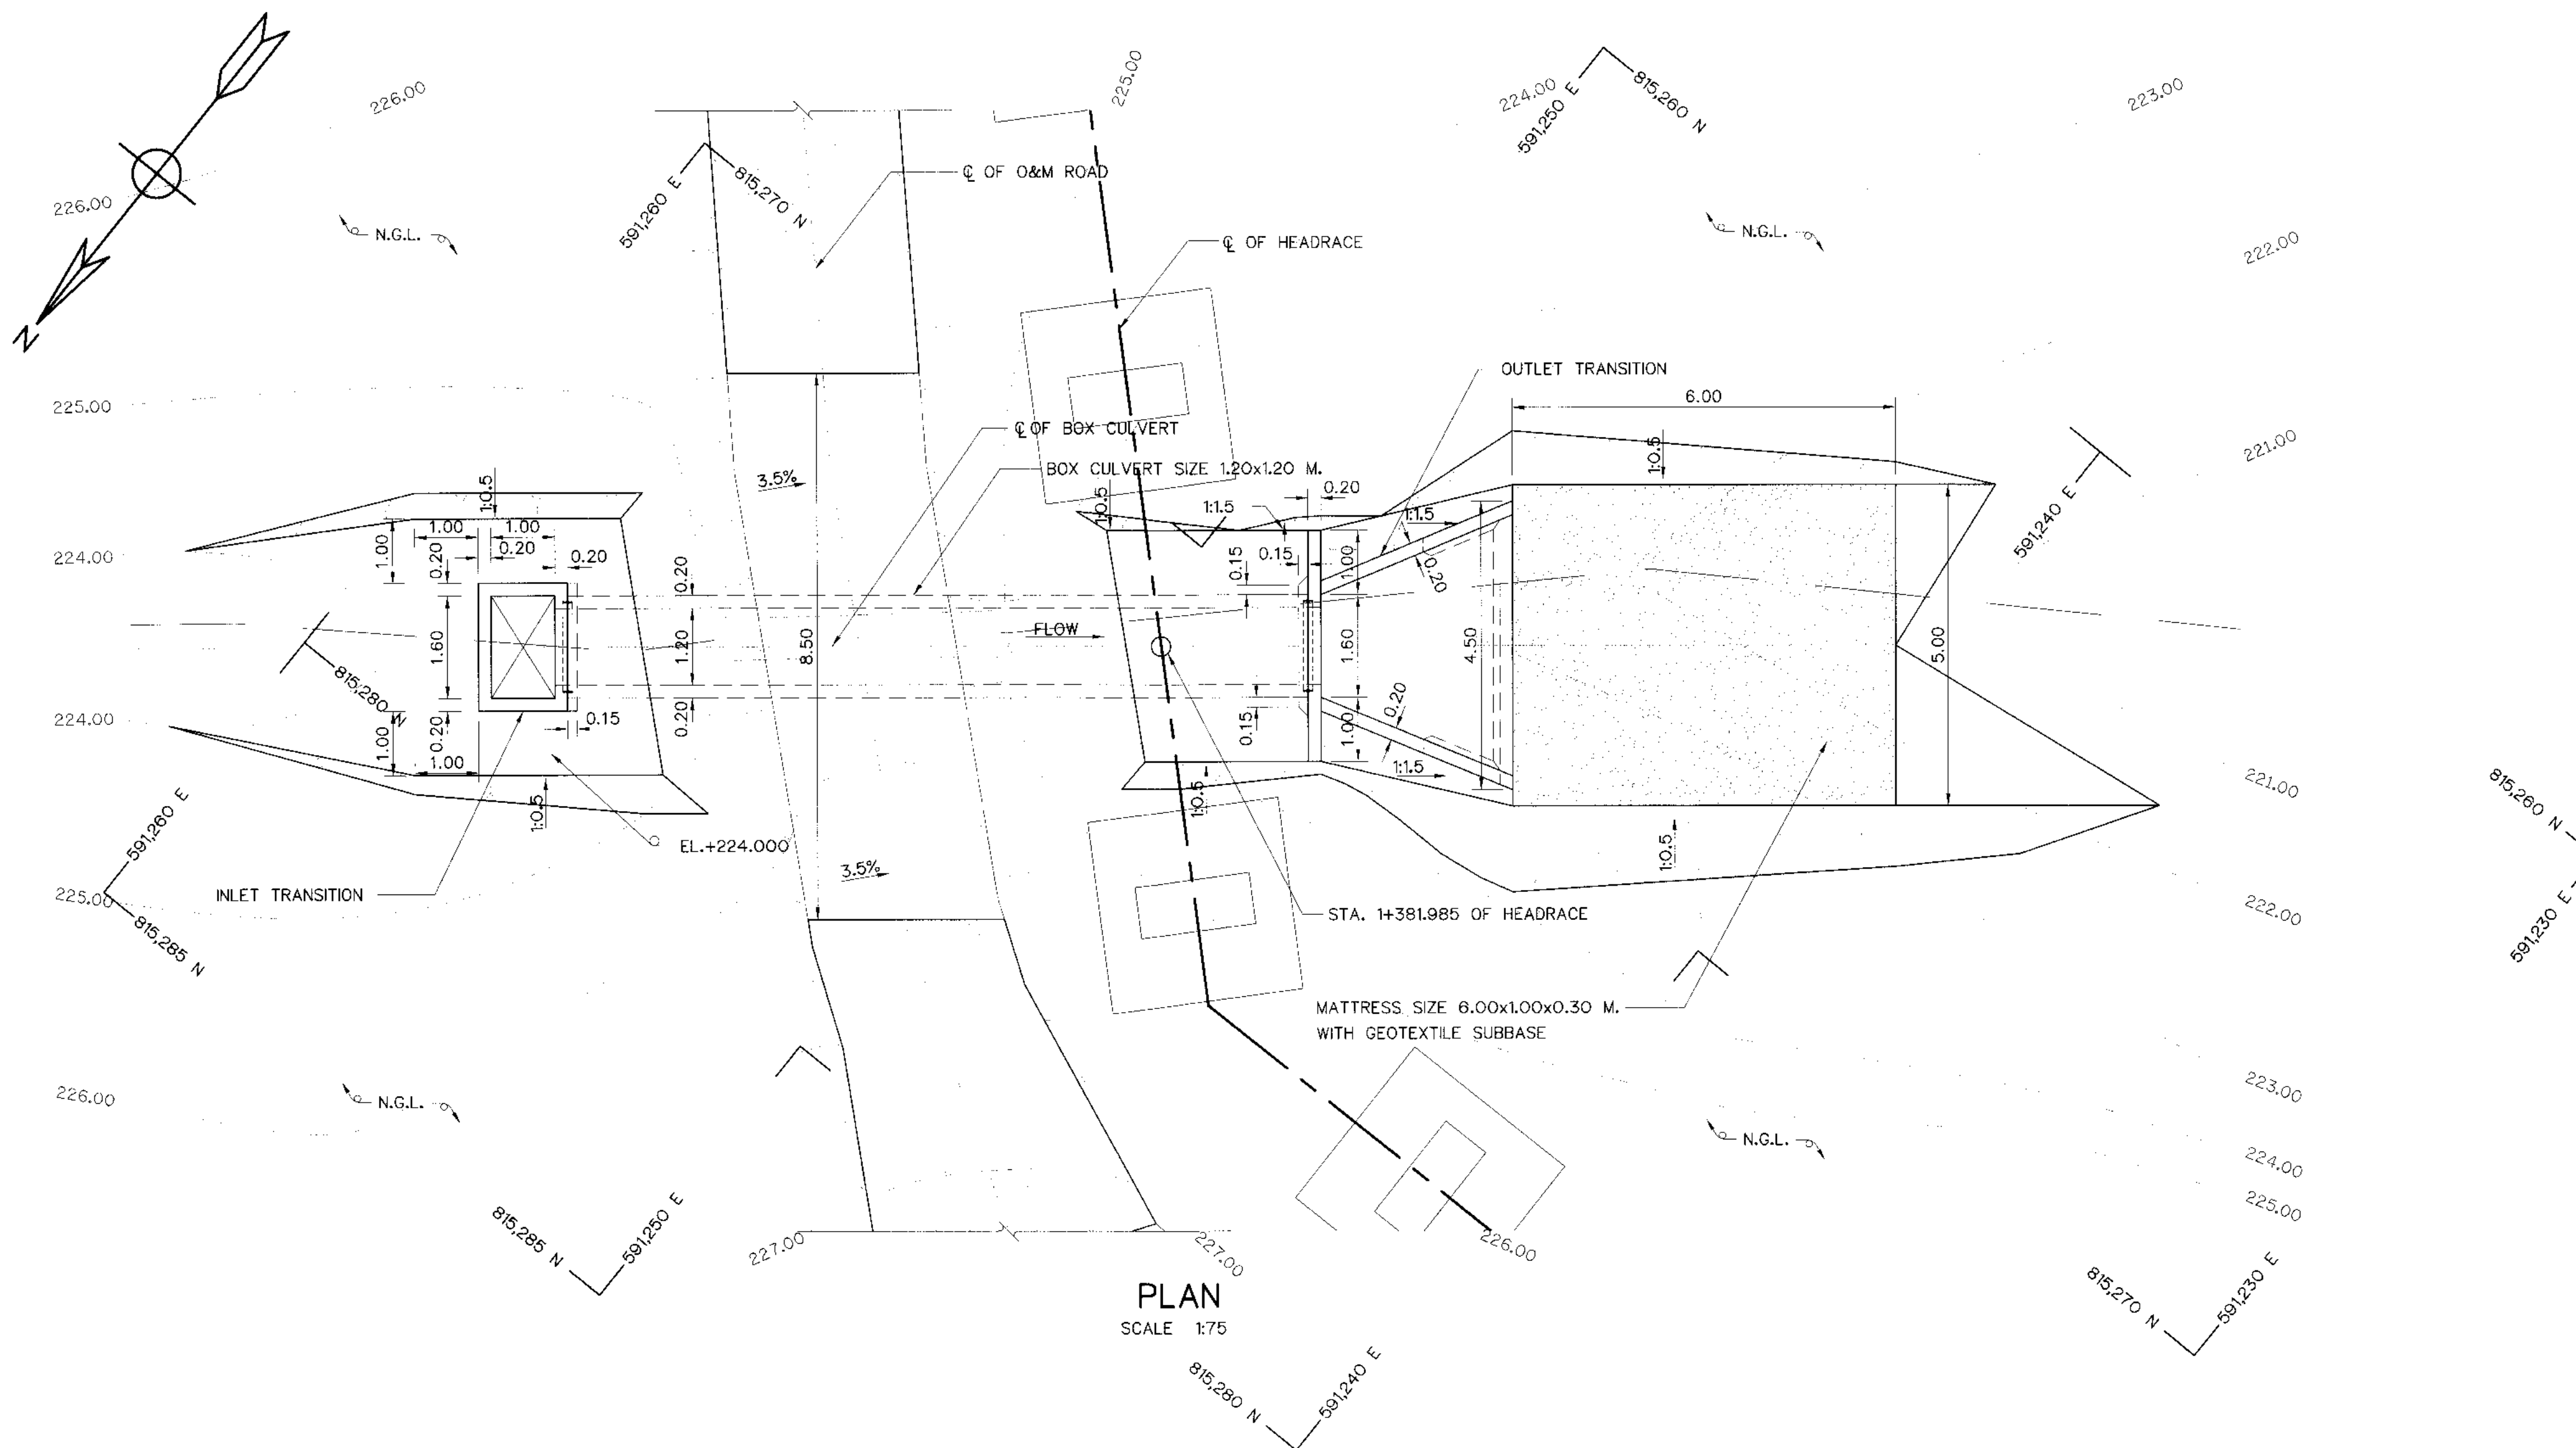


PLAN
SCALE 1:75

- NOTES :
1. ALL DIMENSIONS AND ELEVATIONS (M.S.L.) ARE IN METERS, UNLESS OTHERWISE SHOWN.
 2. SYMBOLS, ABBREVIATIONS AND GENERAL NOTES SEE DWG. NO. KLP-GN-03
 3. THE ALIGNMENT OF THE HEADRACE AND RELATED STRUCTURES SHALL BE CHECK AND CORRECTED BY THE CONTRACTOR TO SUIT THE FIELD CONDITIONS AND SHALL BE SUBMITTED TO DEDE'S FIELD ENGINEER FOR APPROVAL


- REFERENCE DRAWINGS :
1. HEADRACE PLAN AND PROFILE, STA. 1+000 TO STA. 1+459.506 KLP-HR-05
 2. HEADRACE DRAIN CULVERT DETAILS OF REINFORCEMENT KLP-HR-21
 3. HEADRACE TYPICAL SECTIONS AND DETAIL KLP-HR-06

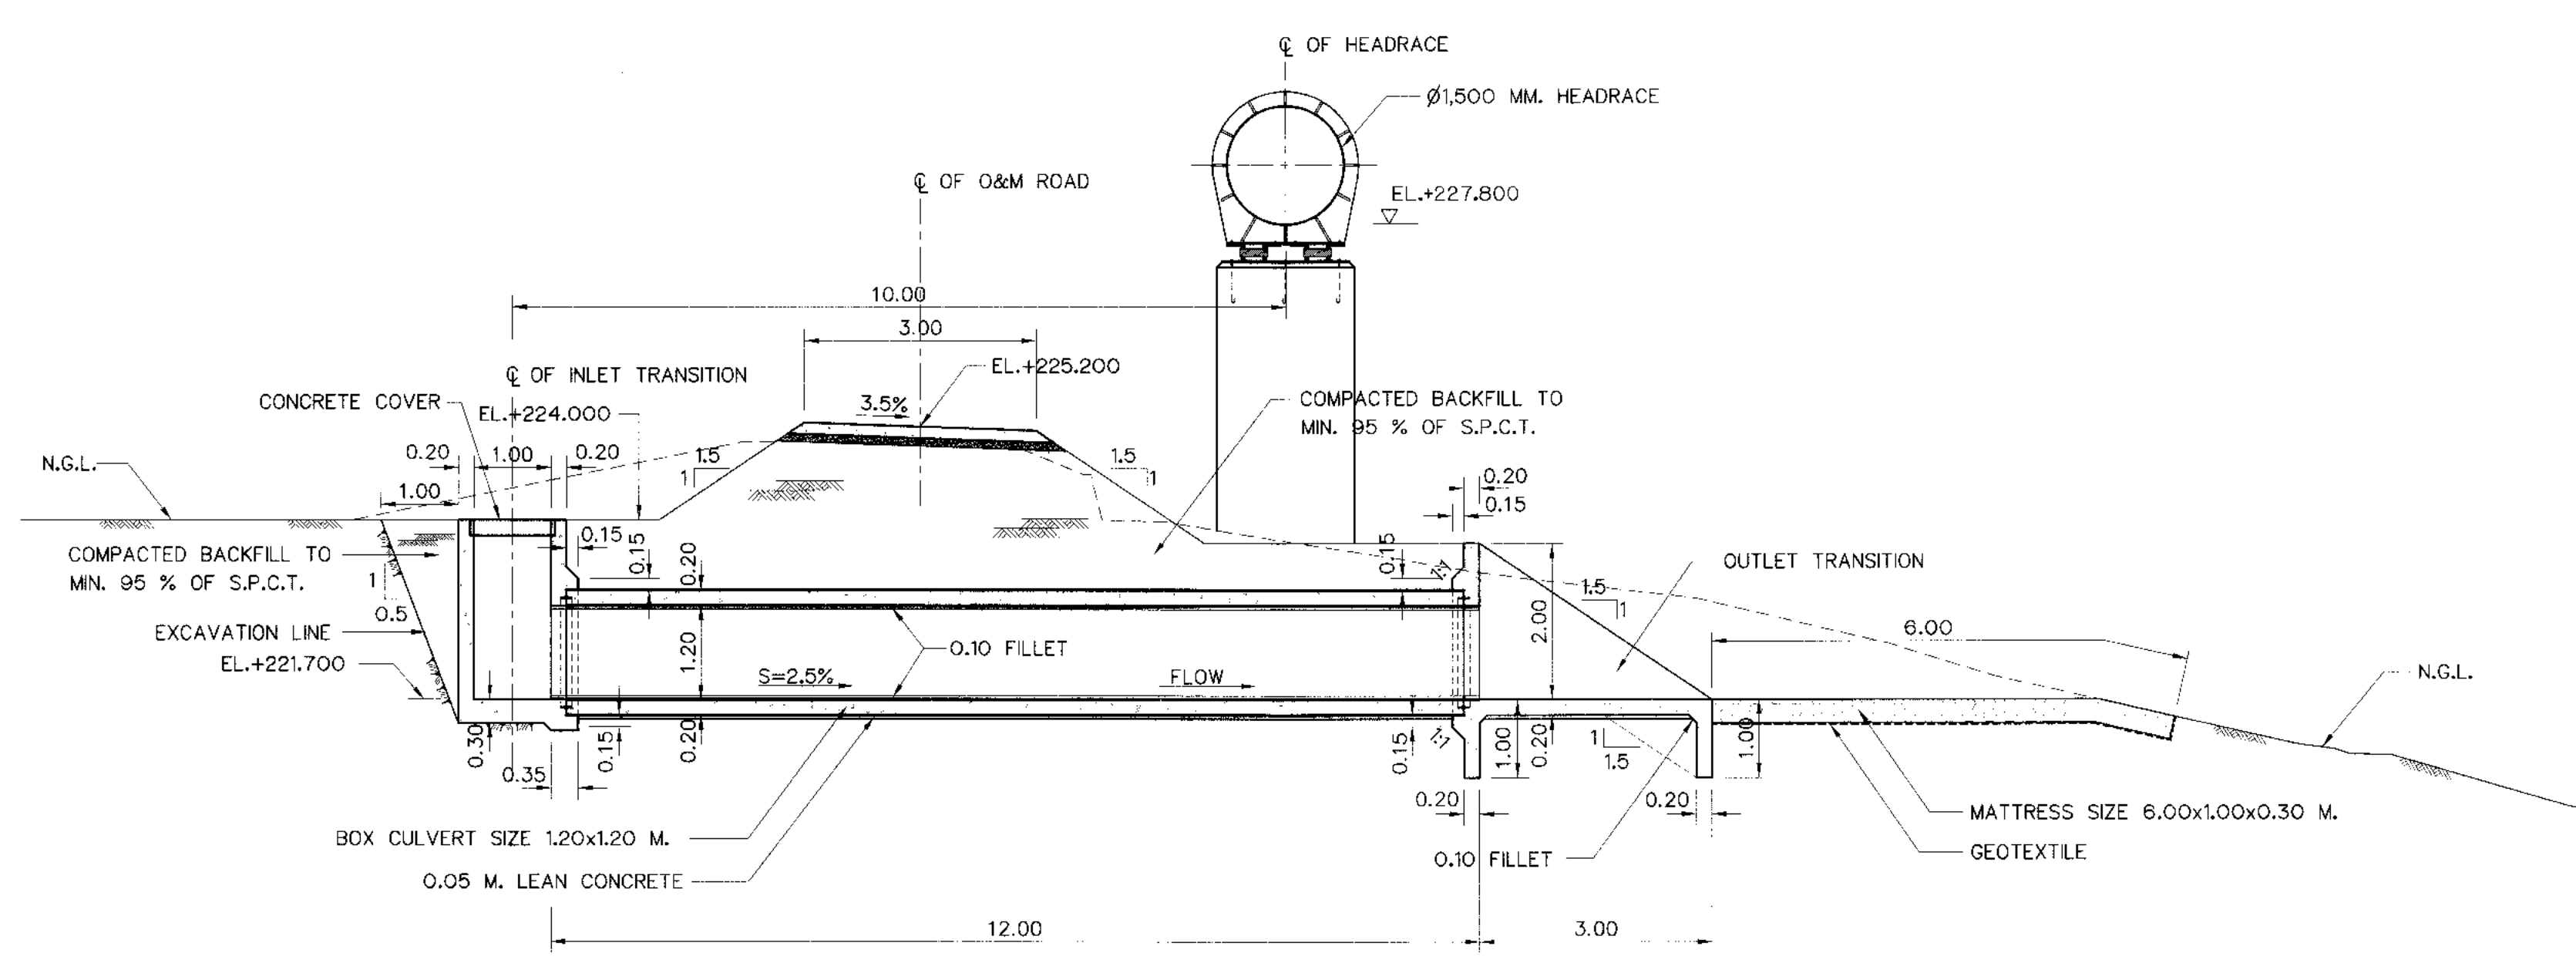


SECTION A-A
SCALE 1:75

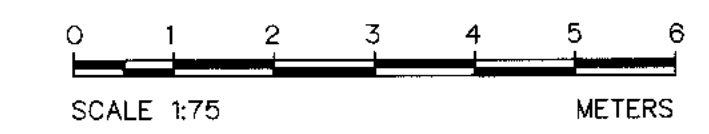


KINGDOM OF THAILAND Department of Alternative Energy Development and Efficiency MINISTRY OF ENERGY	
KLONG LAM PLOK HYDROPOWER PROJECT	
CIVIL WORKS AND TRANSMISSION LINE HEADRACE DRAIN CULVERT STA. 1+381.985 , PLAN AND SECTION	
DESIGNED <i>W. 19.28074</i> 281.6228 DRAWN <i>W. 19.28074</i> 281.6228 NO. DATE REVISIONS CHECKED APPROVED CONSULTANTS DEDE	REVIEWED <i>W. 19.28074</i> 281.6228 SUBMITTED <i>W. 19.28074</i> 281.6228 RECOMMENDED <i>W. 19.28074</i> 281.6228 APPROVED <i>W. 19.28074</i> 281.6228 PROJECT MANAGER DATE
P&C MANAGEMENT CO.,LTD.	MINISTRY OF ENERGY
DRAWING NO. KLP-HR-20	SHEET NO. 43 OF 110

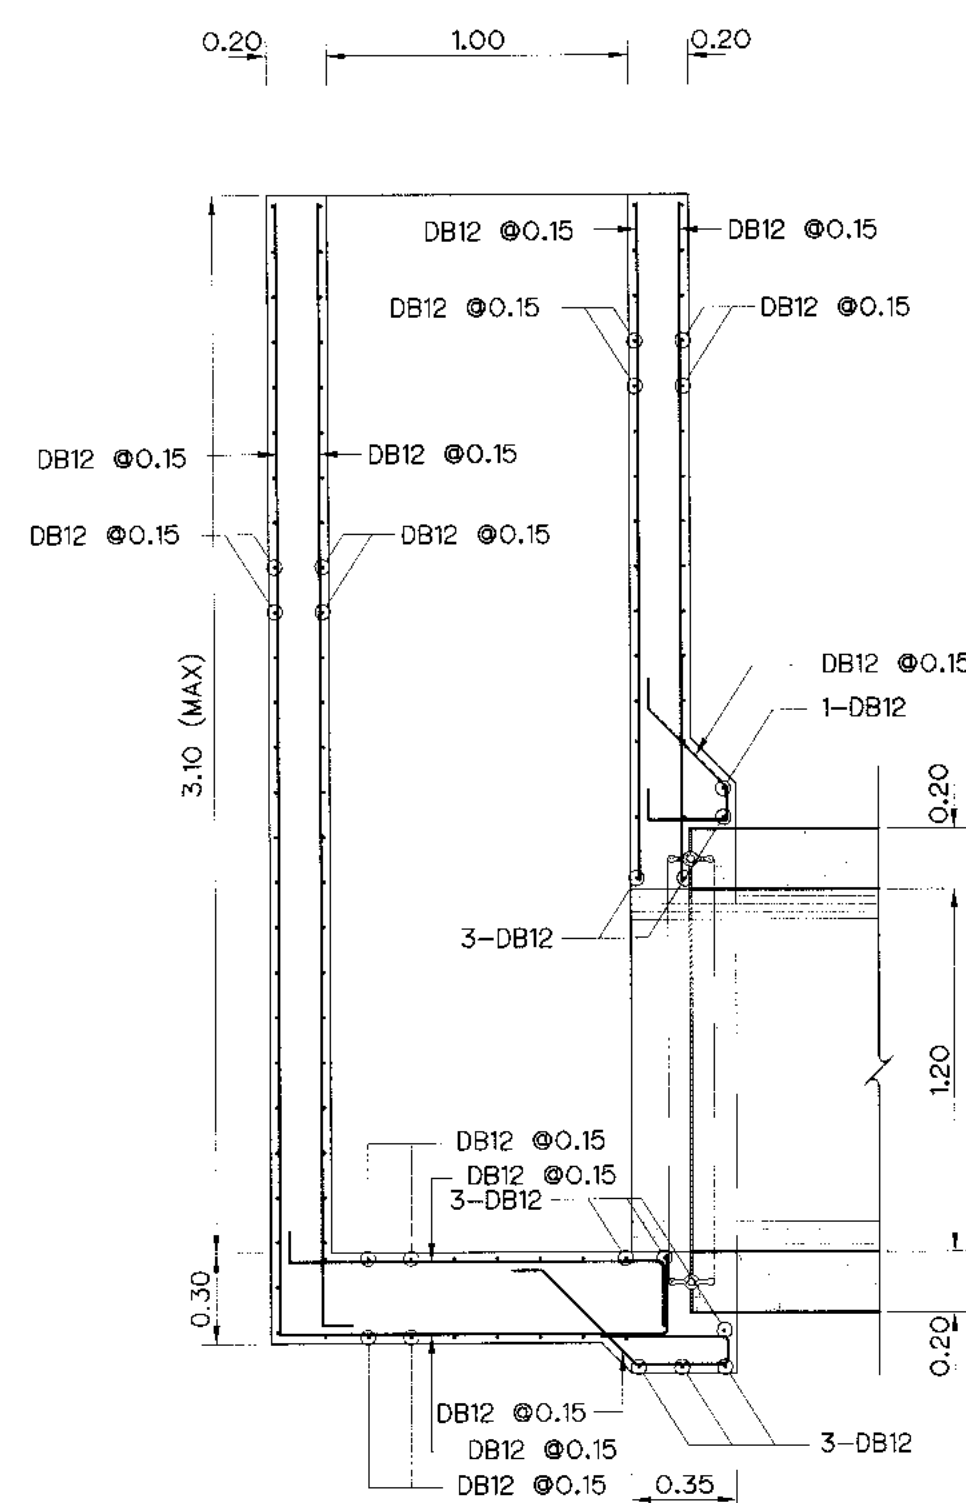


INLET DETAILS
SCALE 1:25

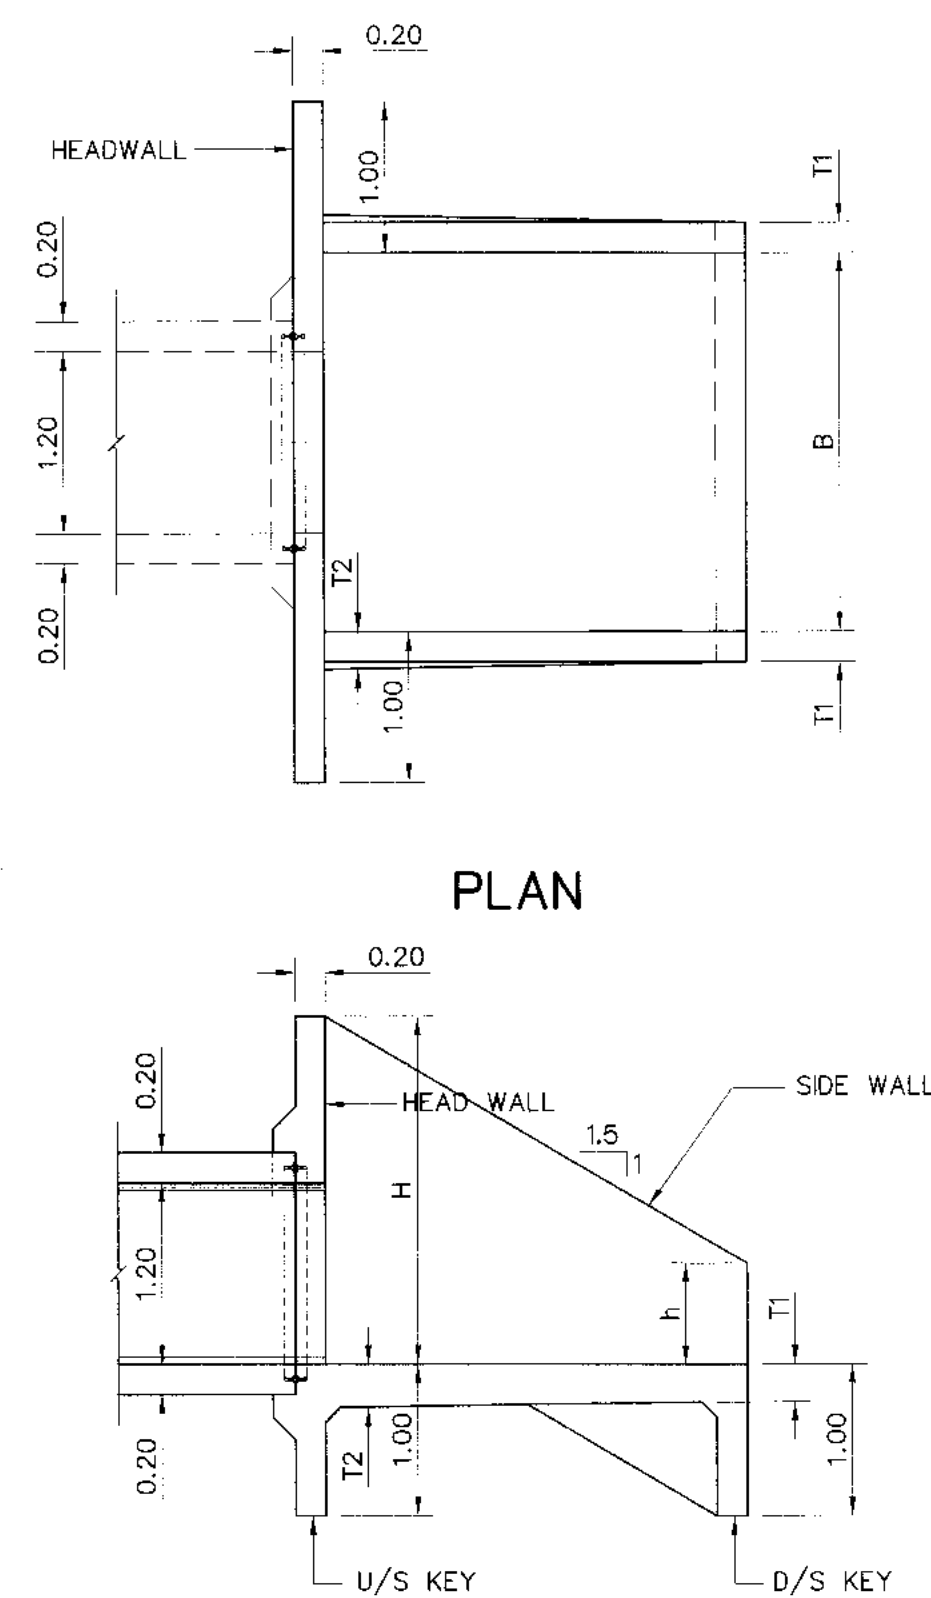


SECTION
TYPE 1 OUTLET

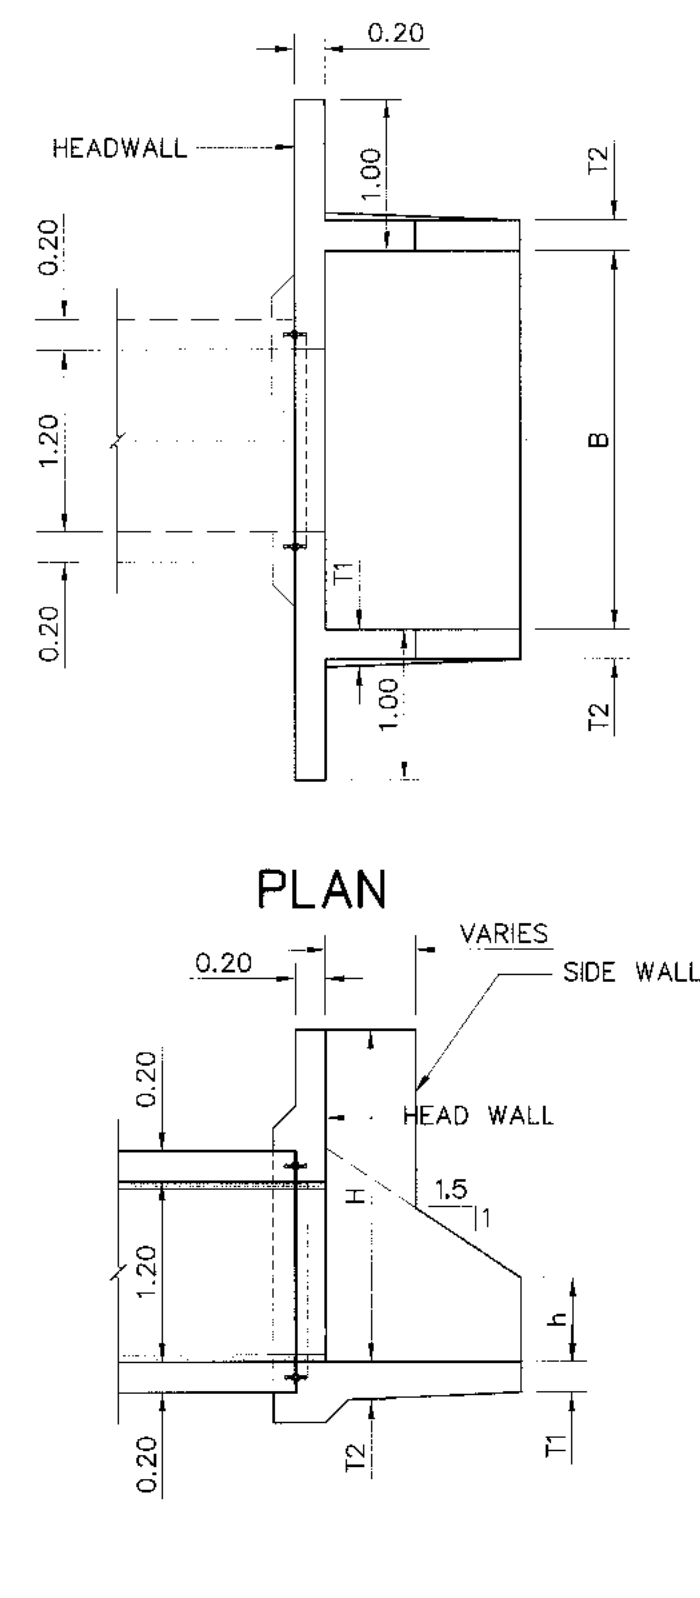


SECTION
TYPE 2 OUTLET

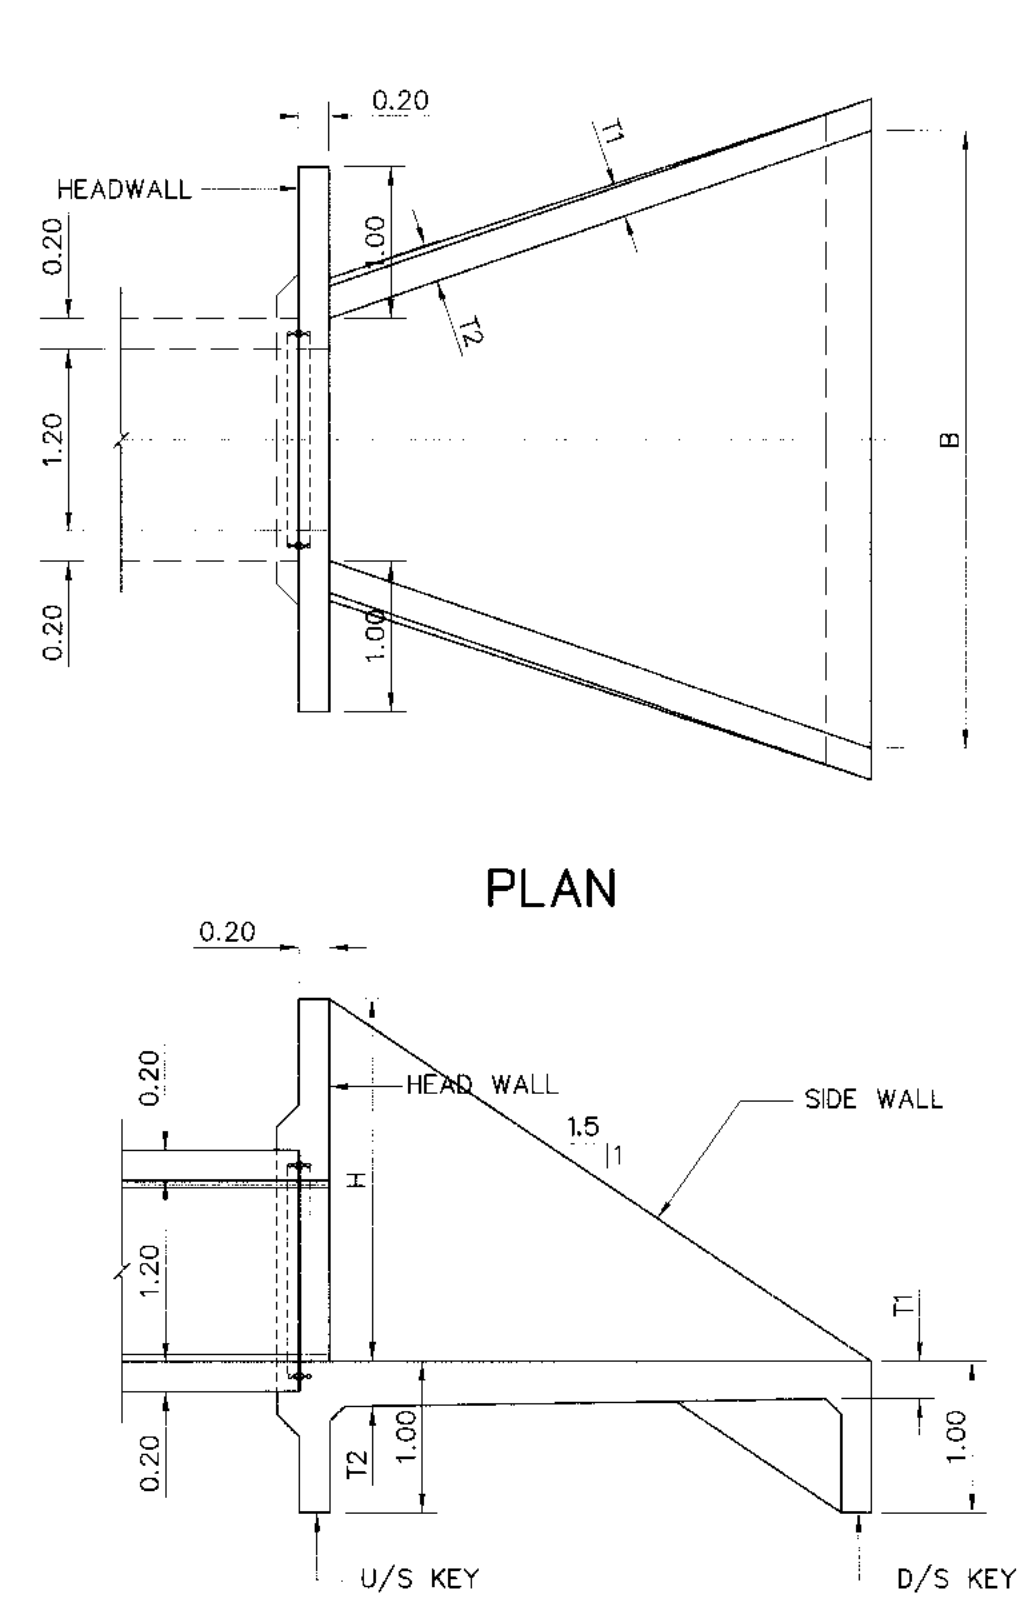


SECTION
TYPE 3 OUTLET

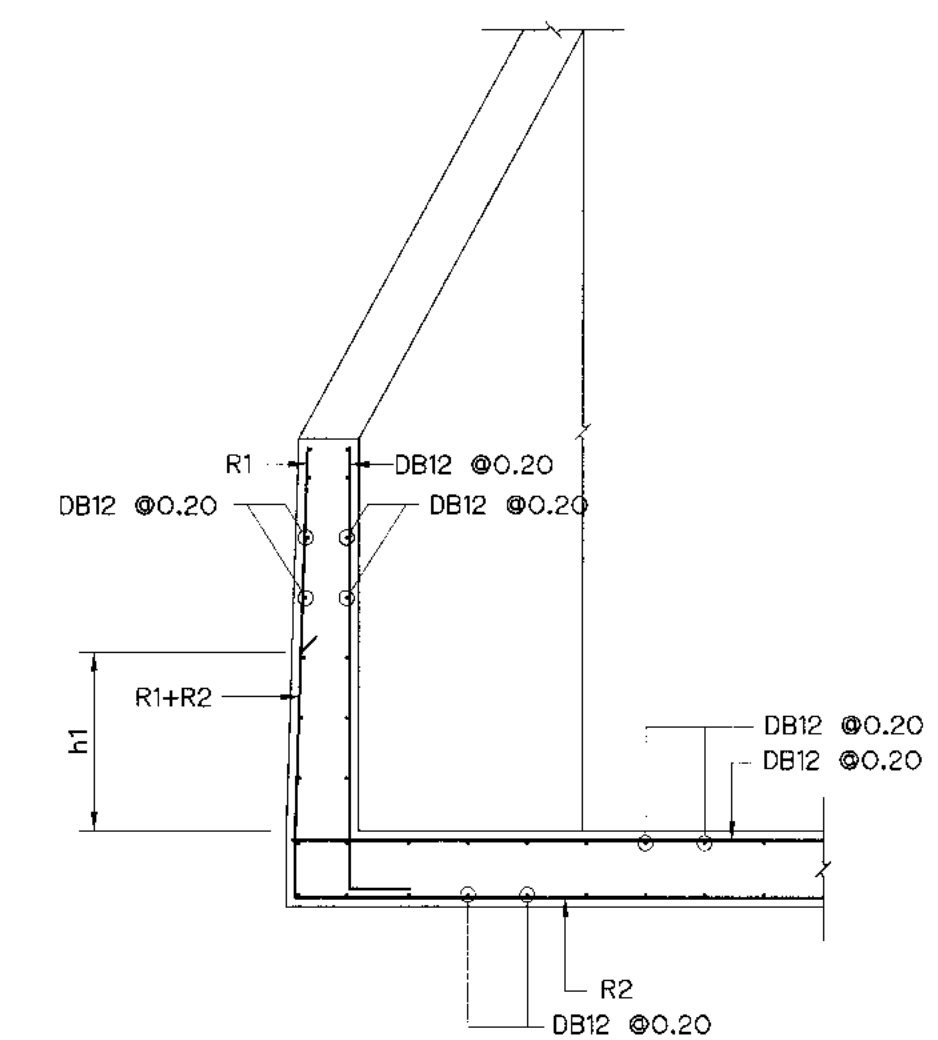


REINFORCEMENT OF SIDEWALL
SCALE 1:25

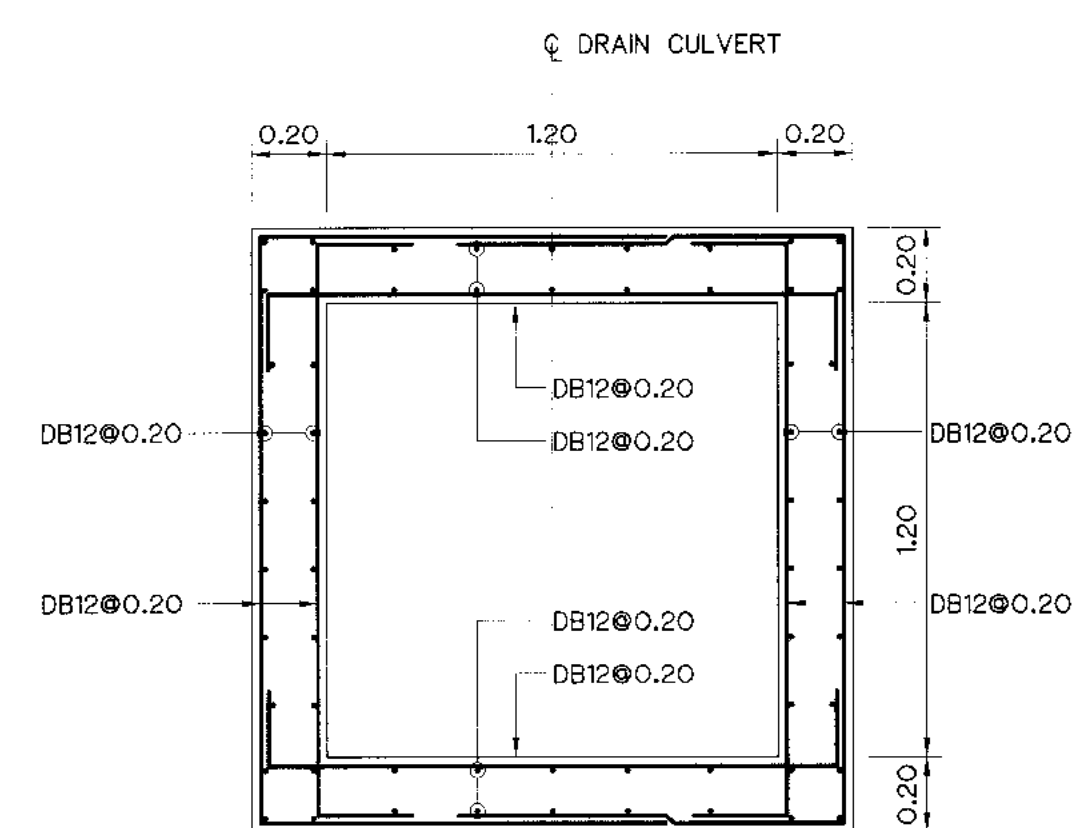

REINFORCEMENT OF BOX CULVERT

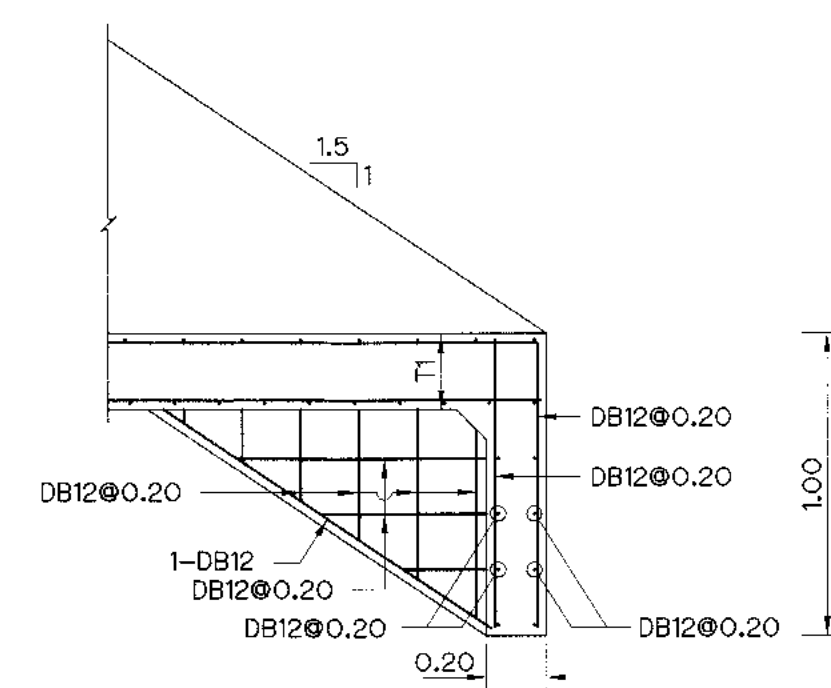

REINFORCEMENT OF D/S KEY
SCALE 1:25

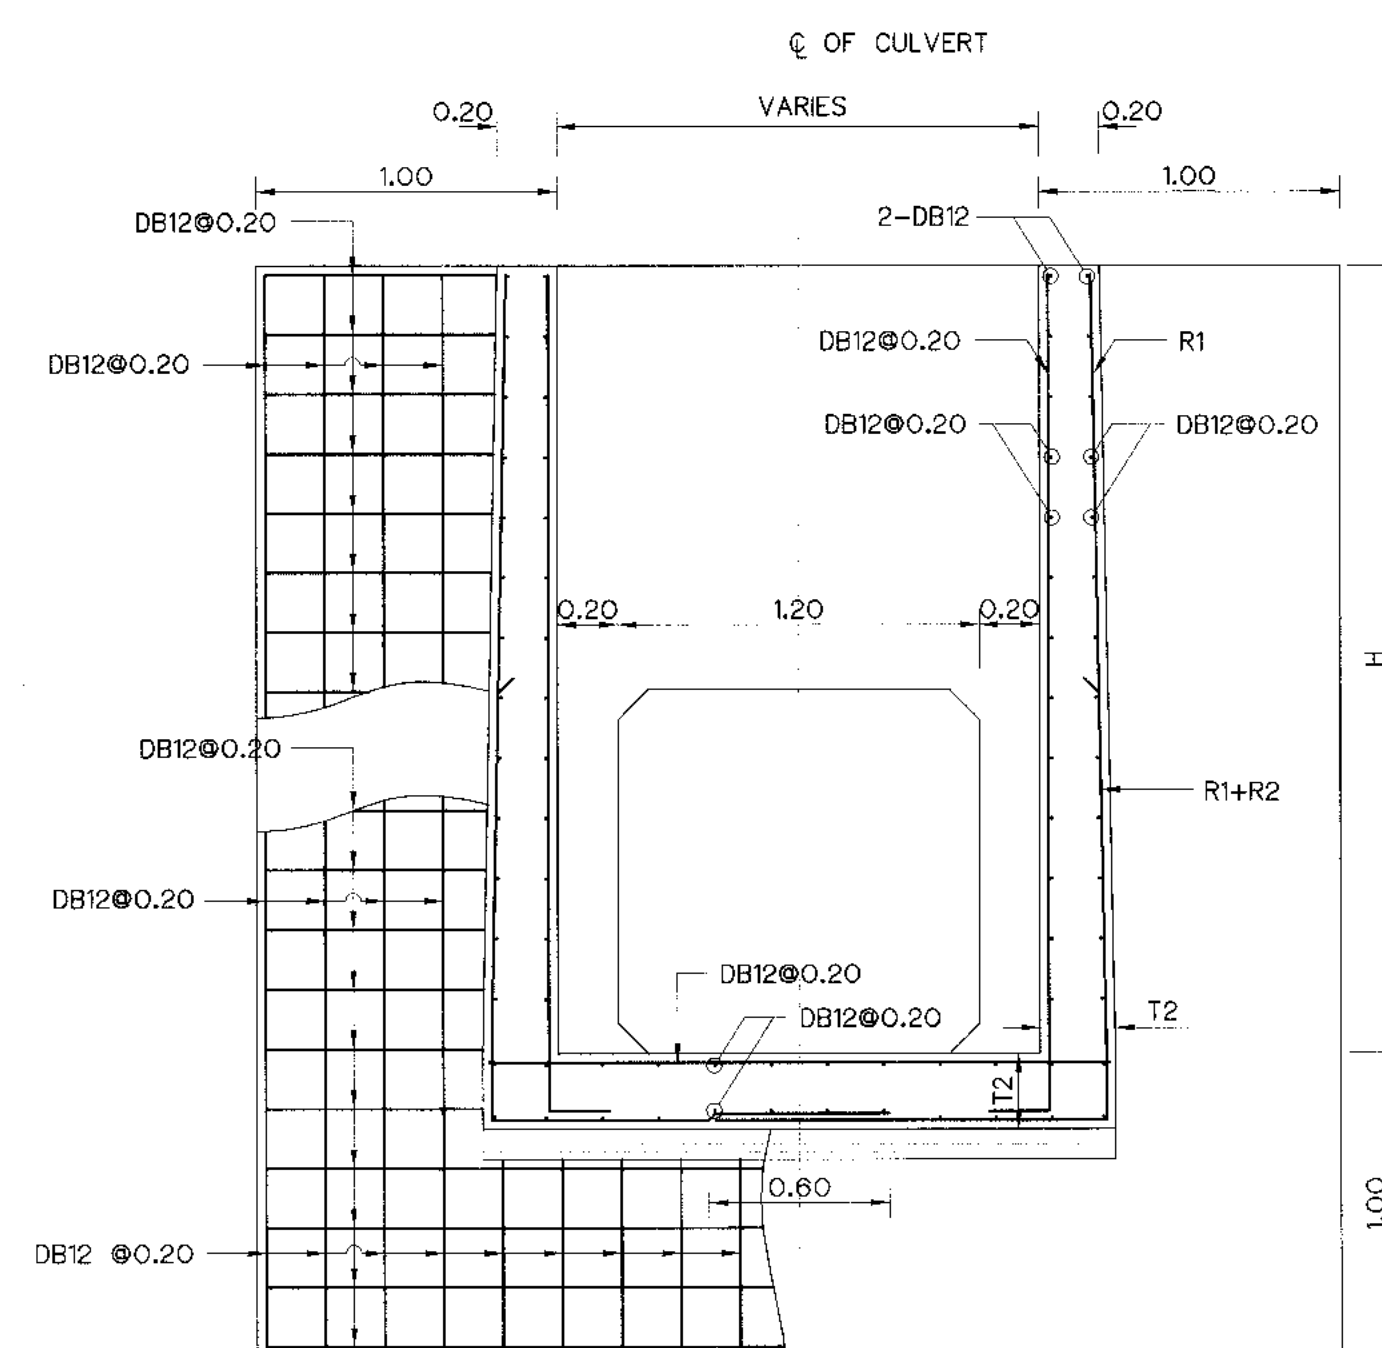


REINFORCEMENT OF HEADWALL

SCALE 1:25

- NOTES :**
1. ALL DIMENSIONS AND ELEVATIONS (M.S.L.) ARE IN METERS,
UNLESS OTHERWISE SHOWN.
 2. SYMBOLS, ABBREVIATIONS AND GENERAL NOTES SEE DWG. NO. KLP-GN-03
 3. CONCRETE DESIGN BASED ON THE COMPRESSIVE STRENGTH OF 210 KSC,
STANDARD CYLINDER $\phi 0.15 \times 0.30$ m. TEST AT AGE 28 DAYS. UNLESS
OTHERWISE INDICATED IN SPECIFIC DRAWINGS.


TABLE OF DIMENSIONS AND REINFORCEMENT

H/h (m.)	h1 (m.)	T1/T2 (m.)	R ①	R ②
< 1.70	—	0.20	DB12@0.20	—
< 2.00	—	0.25	DB12@0.20	—
< 2.50	0.50	0.25	DB12@0.20	DB12@0.20
< 3.00	1.50	0.30	DB12@0.20	DB16@0.20
< 3.50	1.50	0.35	DB16@0.20	DB16@0.20

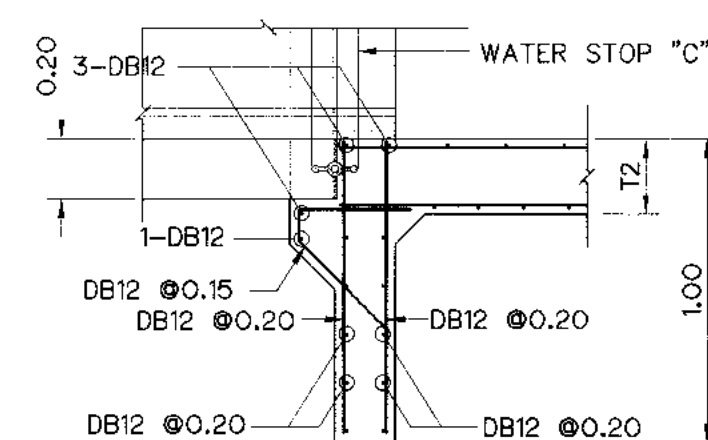


REINFORCEMENT OF U/S KEY
SCALE 1:25

					P&C MANAGEMENT CO., LTD.		MINISTRY OF ENERGY		
3					DESIGNED	07/29/07	07/29/07	REVIEWED	07/29/07
2					DRAWN	07/29/07	07/29/07	SUBMITTED	07/29/07
1					CHECKED	07/29/07	07/29/07	RECOMMENDED	07/29/07
NO.	DATE	REVISIONS	CHECKED	APPROVED				APPROVED	07/29/07
CONSULTANTS					DEDE			DRAWING NO.	
					PROJECT MANAGER			KLP-HR-21	
					DATE			44 of 110	

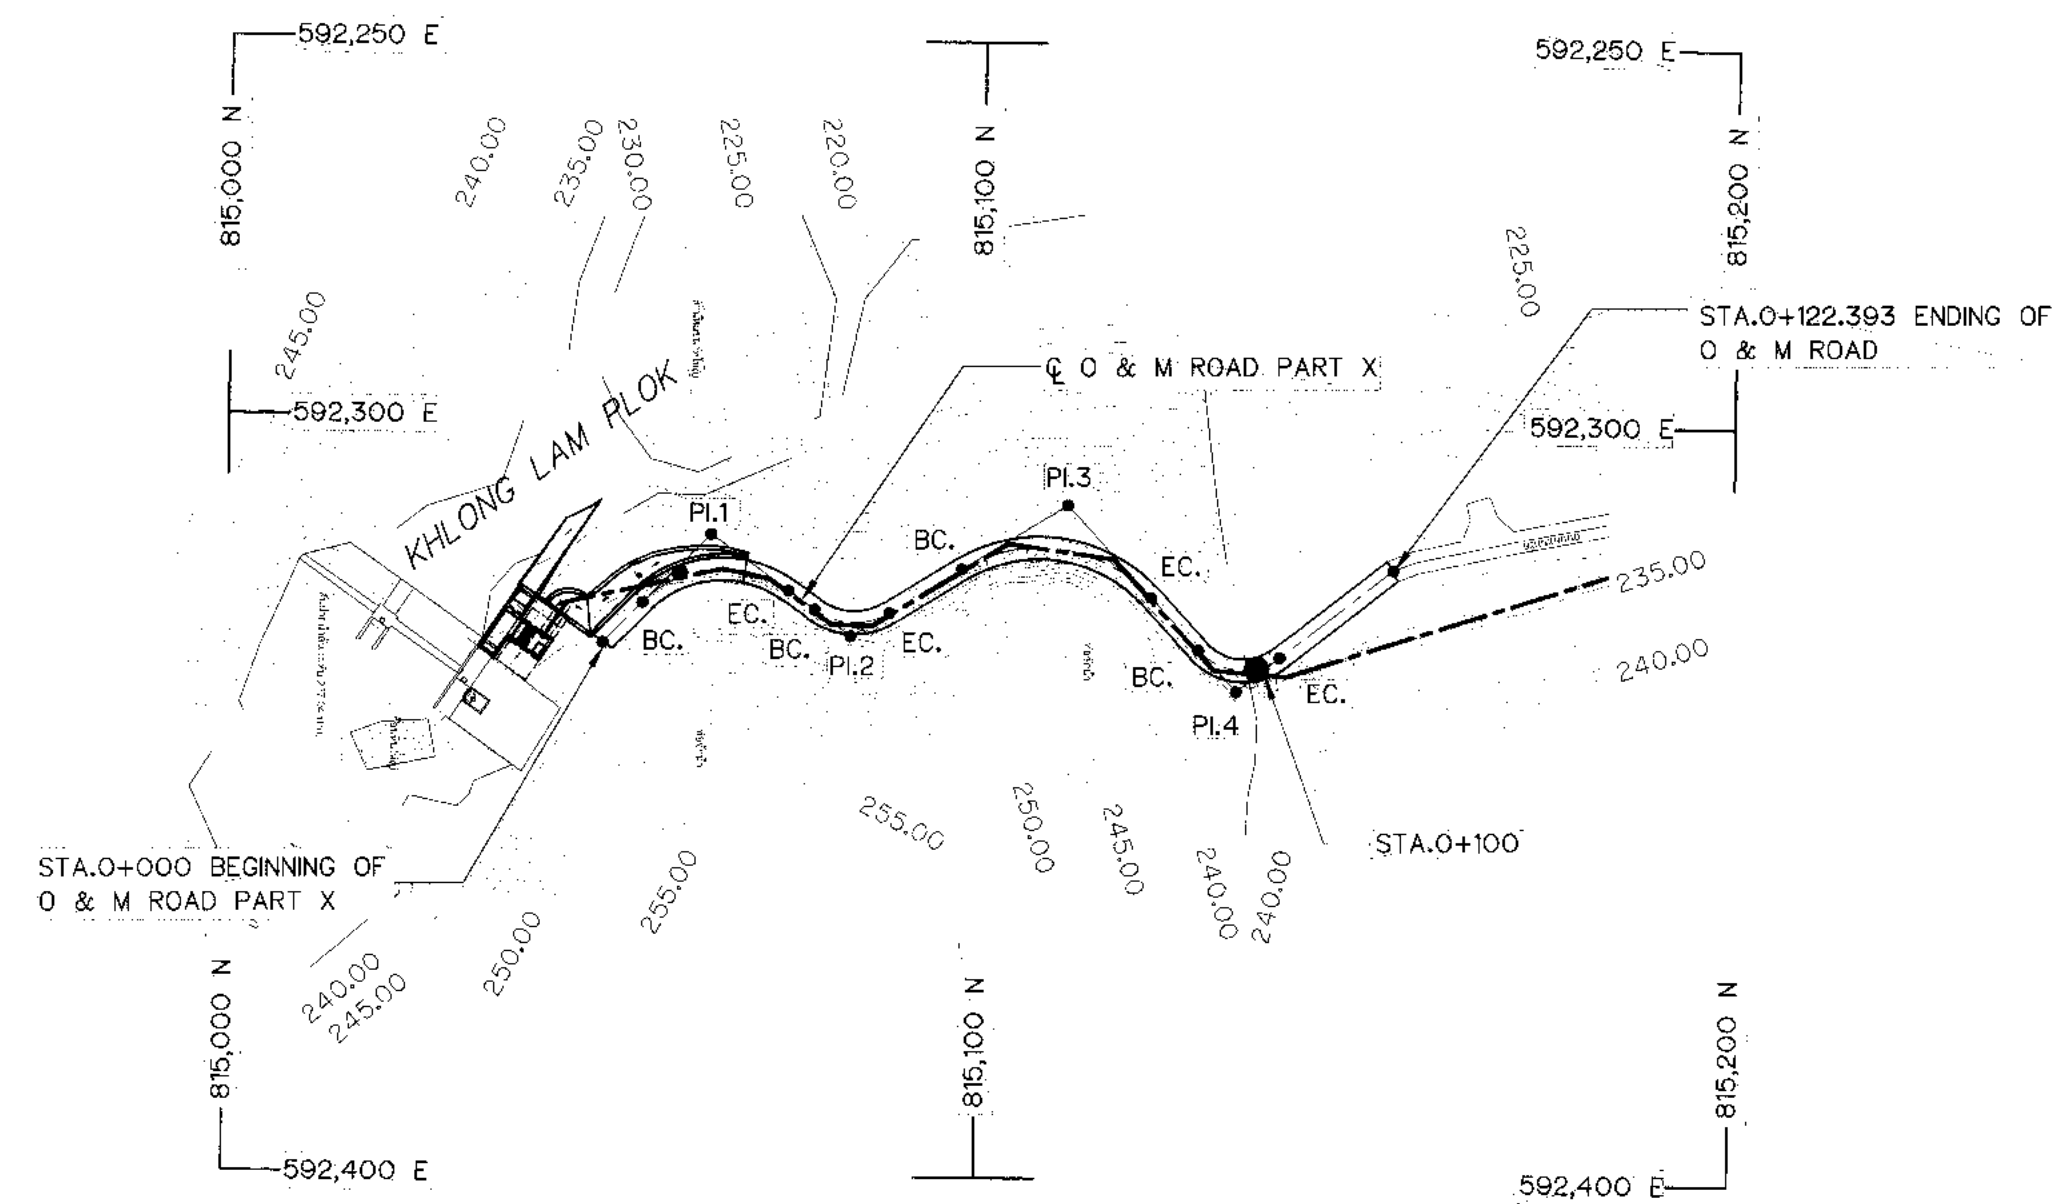

PLAN
SCALE 1:1,000

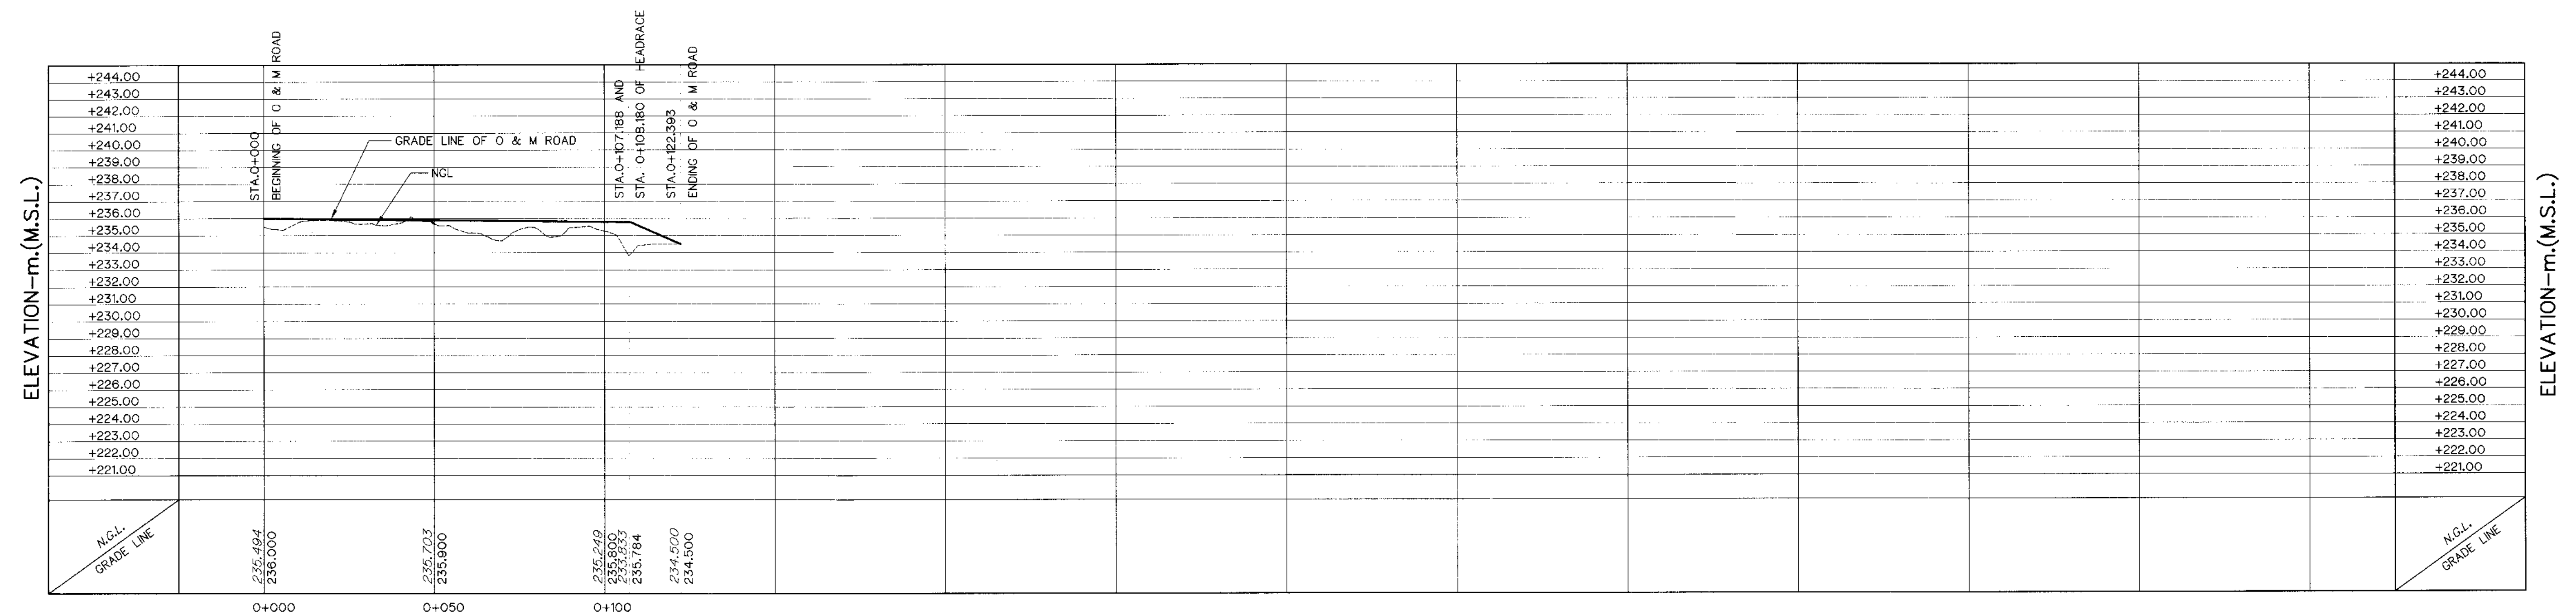

PROFILE

VERTICAL SCALE 1:200

HORIZONTAL SCALE 1:1,000

HORIZONTAL CURVE OF O&M ROAD

NO. PL.	COORDINATE		PL. - PL. (m)	DEFLECTION ANGLE (Δ) (° - ' - ")	TL. (m)	R (m)	L.C. (m)	BC. STA. (km)	PL. STA. (km)	EC. STA. (km)	BEARING (N/S - ° - ' - " E/W)
	N	E									
BEG.	815,049.995	592,329.732	-	-	-	-	-	-	0+000.000	-	-
1	815,064.253	592,315.360	20.245	80°-39'-05.69"	12.733	15.000	21.115	0+007.512	0+020.245	0+028.627	N45°-13'-41.31"W
2	815,082.925	592,328.641	22.914	67°-02'-14.68"	5.961	9.000	10.530	0+032.846	0+038.808	0+043.377	N35°-25'-24.39"E
3	815,111.586	592,310.999	33.656	78°-46'-17.64"	16.420	20.000	27.496	0+054.651	0+071.071	0+082.148	N31°-36'-50.30"W
4	815,134.102	592,335.278	33.113	85°-10'-47.77"	7.354	8.000	11.893	0+091.486	0+098.840	0+103.380	N47°-09'-27.35"E
END	815,154.906	592,319.080	33.553	-	-	-	-	-	0+122.393	-	N38°-01'-20.42"W


NOTES :

1. ALL DIMENSIONS AND ELEVATIONS (M.S.L.) ARE IN METERS UNLESS OTHERWISE SHOWN.
2. SYMBOL, ABBREVIATIONS AND GENERAL NOTES SEE DWG. NO. KLP-GN-03
3. THE ALIGNMENT OF THE HEADRACE AND RELATED STRUCTURES SHALL BE CHECKED AND CORRECTED BY THE CONTRACTOR TO SUIT THE FIELD CONDITIONS AND SHALL BE SUBMITTED TO DDE'S FIELD ENGINEER FOR APPROVAL

REFERENCE DRAWINGS :






- ## 1. O&M ROAD TYPICAL SECTIONS AND DETAILS

KLP-OM-02

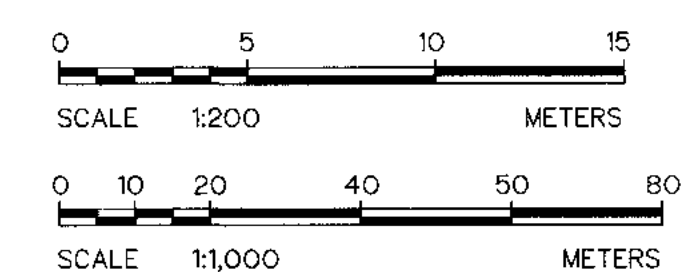



3				
2				
1				
NO.	DATE	REVISIONS	CHECKED	APPROVED
	CONSULTANTS		DEDE	

 KINGDOM OF THAILAND Department of Alternative Energy Development and Efficiency MINISTRY OF ENERGY	
KLONG LAM PLOK HYDROPOWER PROJECT	
CIVIL WORKS AND TRANSMISSION LINE O&M ROAD PLAN AND PROFILE, STA. 0+000 TO STA. 0+107.621	
 P&C MANAGEMENT CO., LTD.	 Department of Alternative Energy Development and Efficiency MINISTRY OF ENERGY
DESIGNED <i>W</i> 218.29074 <i>0.5</i> 26L6228	REVIEWED <i>Chenit</i>
DRAWN <i>gao</i>	SUBMITTED <i>Chenit</i>
CHECKED <i>0.5</i> 26L6228	RECOMMENDED <i>0.5</i>
<i>OR</i> PROJECT MANAGER <i>08/03/2559</i> DATE	APPROVED <i>P. Harnell</i>
	DRAWING NO. KLP-OM-01 SHEET NO. 46 of 110

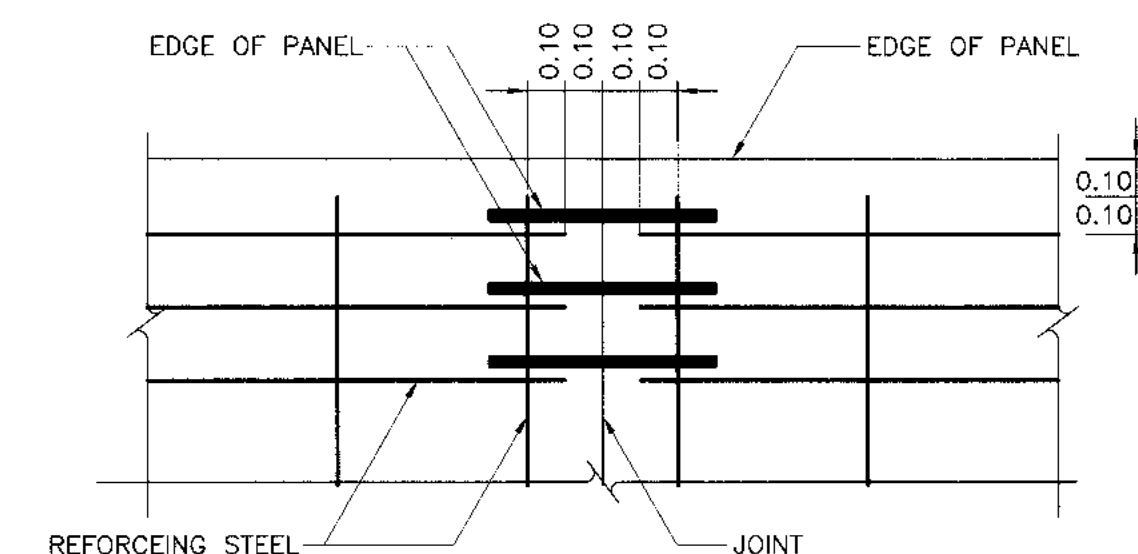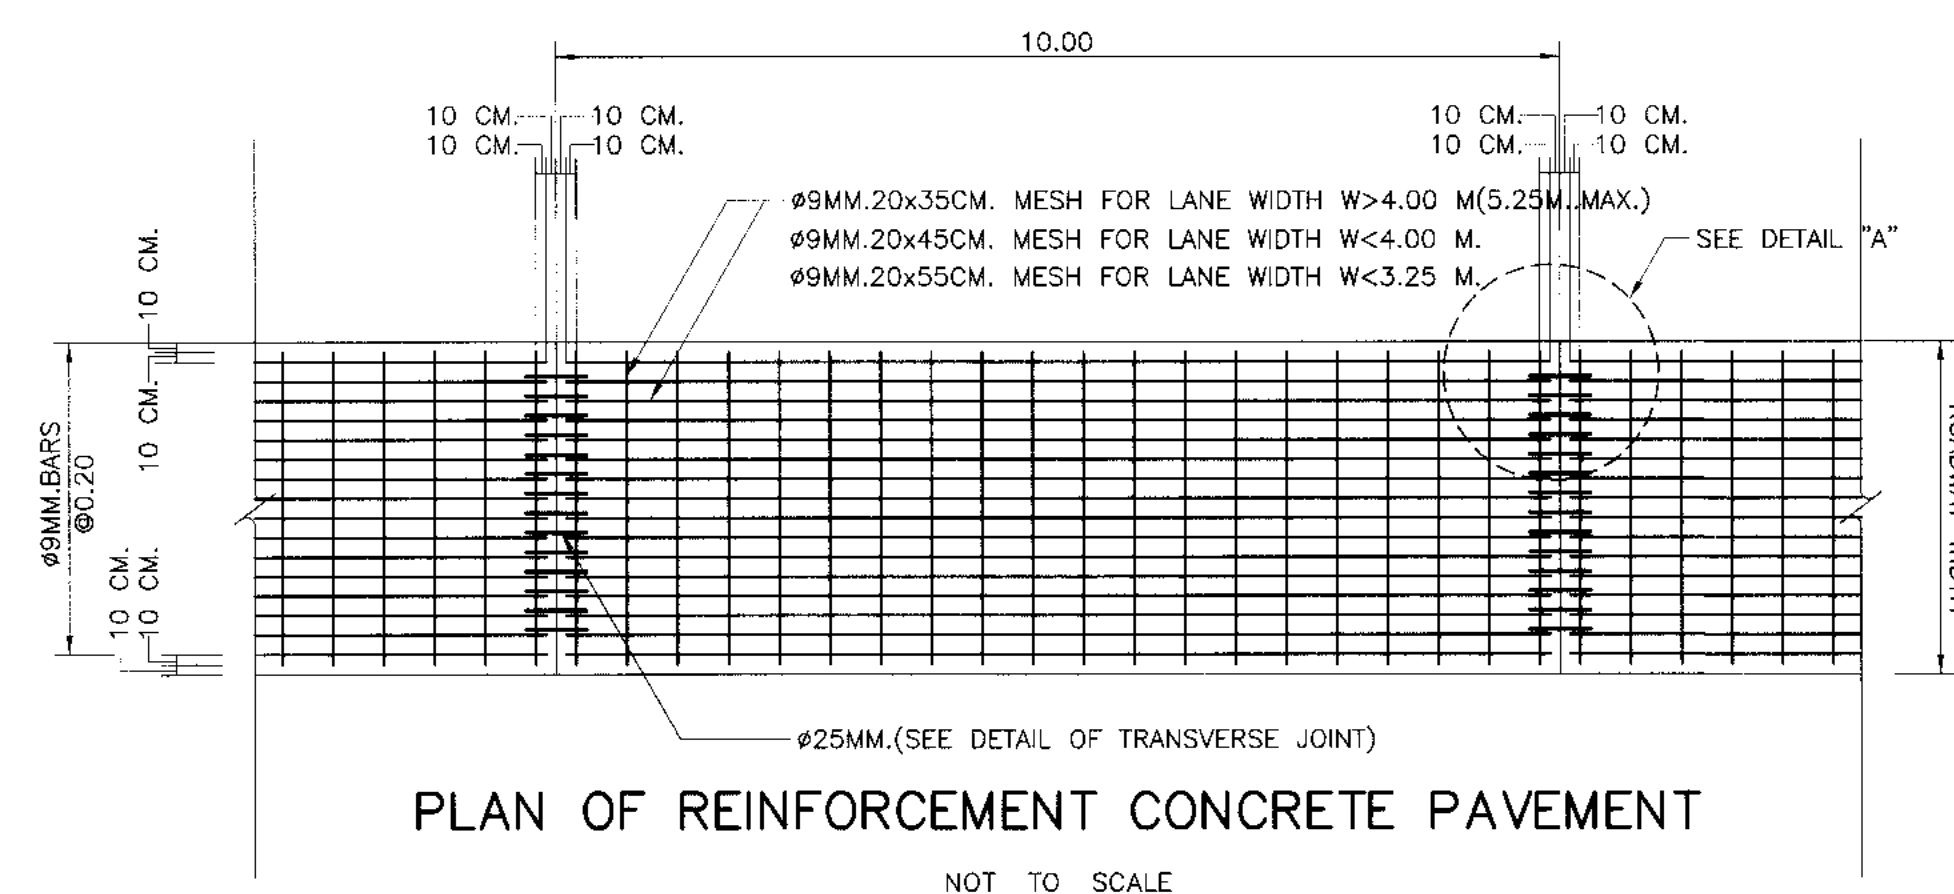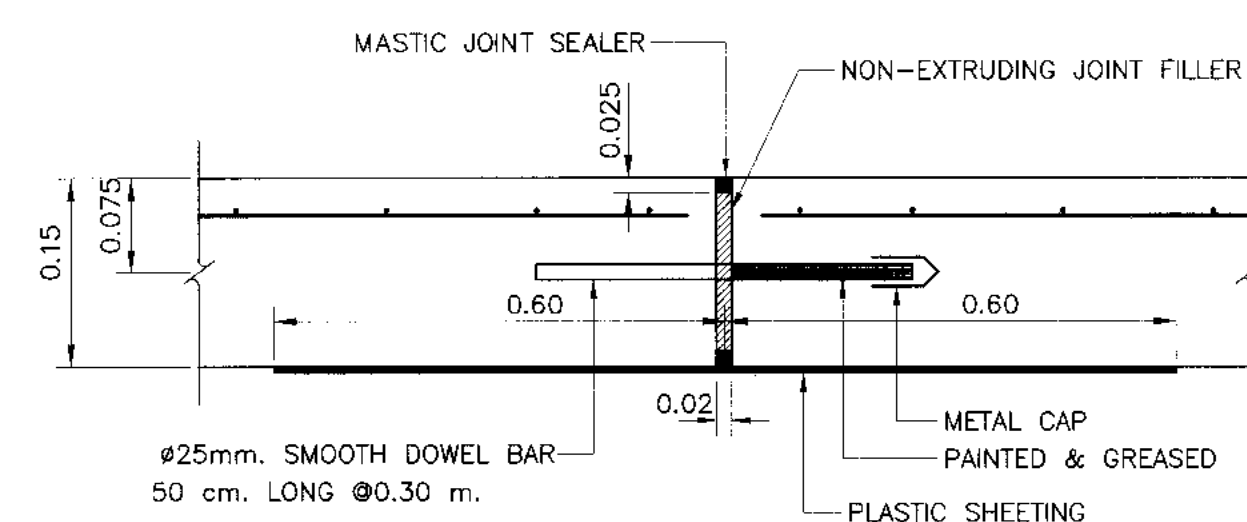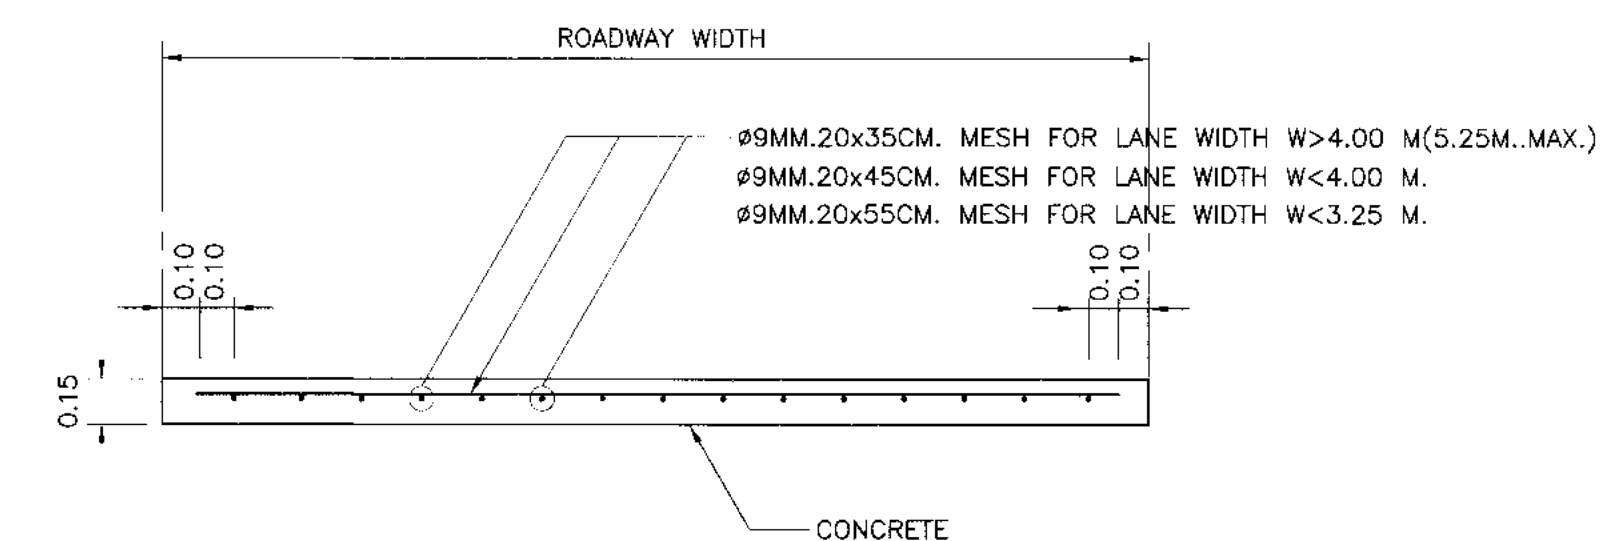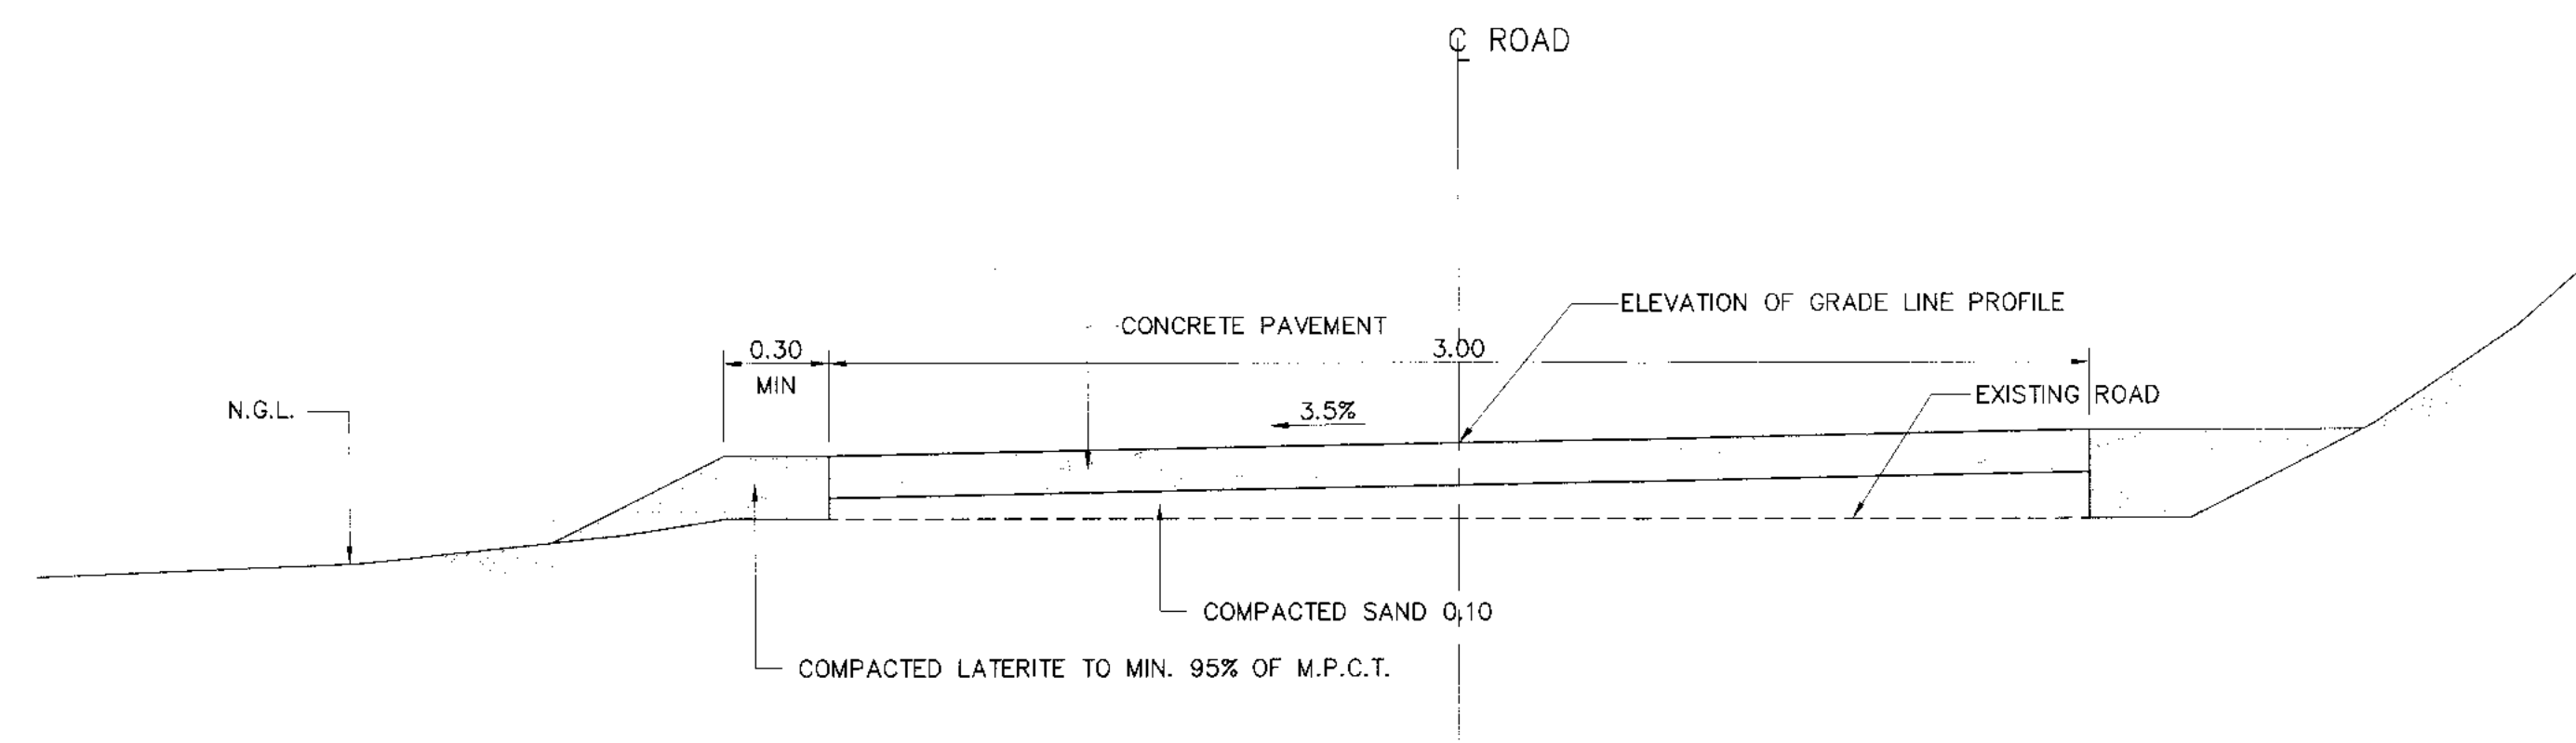

NOTES 1 :


1. ALL DIMENSIONS ARE IN METERS UNLESS OTHERWISE INDICATED.
2. EXPANSION JOINT SHALL BE CONSTRUCTED AT THE INTERVAL OF 90 METERS.
3. MASTIC JOINT SEALER SHALL BE OF THE HOT POURED ELASTIC TYPE CONFORMING TO TIS.479.
4. JOINT FILLER SHALL CONFORM TO THE AASHTO M.213-74 OR ASTM.D1751-73 SPECIFICATION.
5. CONCRETE SHALL HAVE A MINIMUM ULTIMATE COMPRESSIVE STRENGTH OF 300 KSC. FOR 15x15x15 CM. CUBE AT 28 DAYS.
6. REINFORCING STEEL SHALL CONFORM TIS.20 GRADE SR 24 FOR ROUND BARS AND TIS.24 GRADE SD 30 FOR DEFORMED BAR.
7. PLASTIC SHEET USED IN CONSTRUCTION SHALL HAVE THE FOLLOWING REQUIREMENTS :
 - 7.1 THICKNESS OF 0.07 MM. WITH A TOLERANCE OF NOT MORE THAN 7 % SHALL BE REQUIRED.
 - 7.2 WIDTH SHALL NOT BE LESS THAN 1.20 M.
 - 7.3 IT SHALL BE COLOURLESS, TRANSPARENT AND WATERPROOF, FREE FROM POROUS AREA, TURN AREA AND BLISTERING AREA WHICH ARE VISIBLE BY NAKED EYE. EDGE SHALL BE STRAIGHT.
 - 7.4 CONTINUOUS LENGTH SHALL BE REQUIREMENT TO THE WIDTH OF TRAFFIC LANES. CONNECTION ALLOWED AT LONGITUDINAL JOINTS WITH NOT LESS THAN 20 CM. OVERLAPPING SHALL BE REQUIRED.

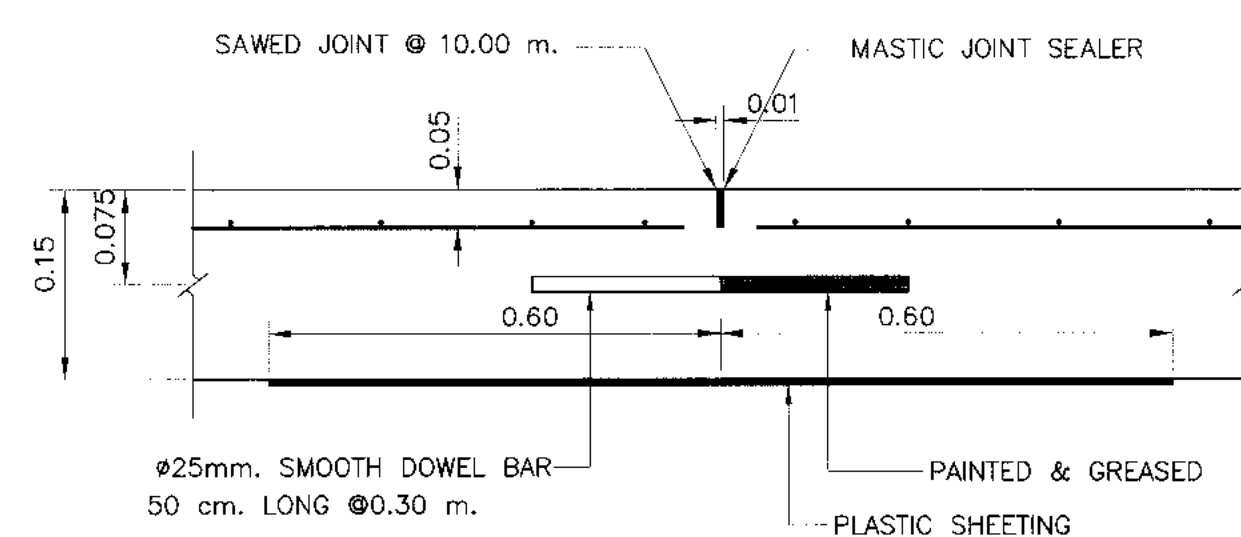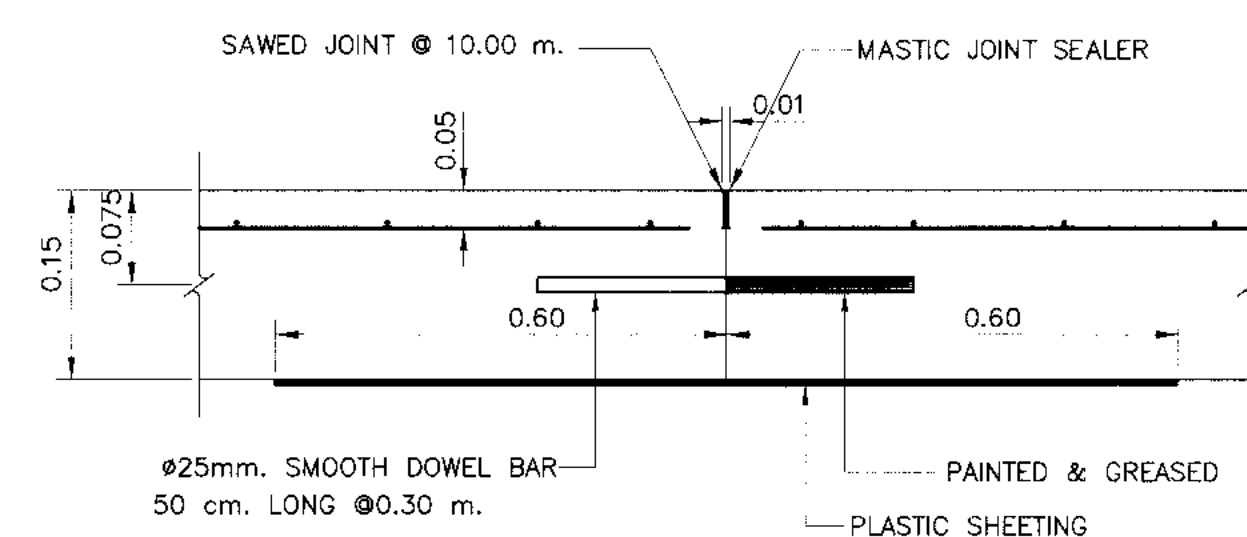


REFERENCE DRAWINGS :

1. O&M ROAD PLAN AND PROFILE, KLP-OM-01


3						P&C MANAGEMENT CO.,LTD.	MINISTRY OF ENERGY
2						DESIGNED <i>[Signature]</i> 29/07/89 29/07/89	REVIEWED <i>[Signature]</i>
1						DRAWN <i>[Signature]</i>	SUBMITTED <i>[Signature]</i>
NO.	DATE	REVISIONS	CHECKED	APPROVED	CHECKED	29/07/89 29/07/89	RECOMMENDED <i>[Signature]</i>
	CONSULTANTS		DEDE		<i>[Signature]</i>	08/03/2550	DRAWING NO. KLP-OM-02
					PROJECT MANAGER	DATE	SHEET NO. 47 OF 110

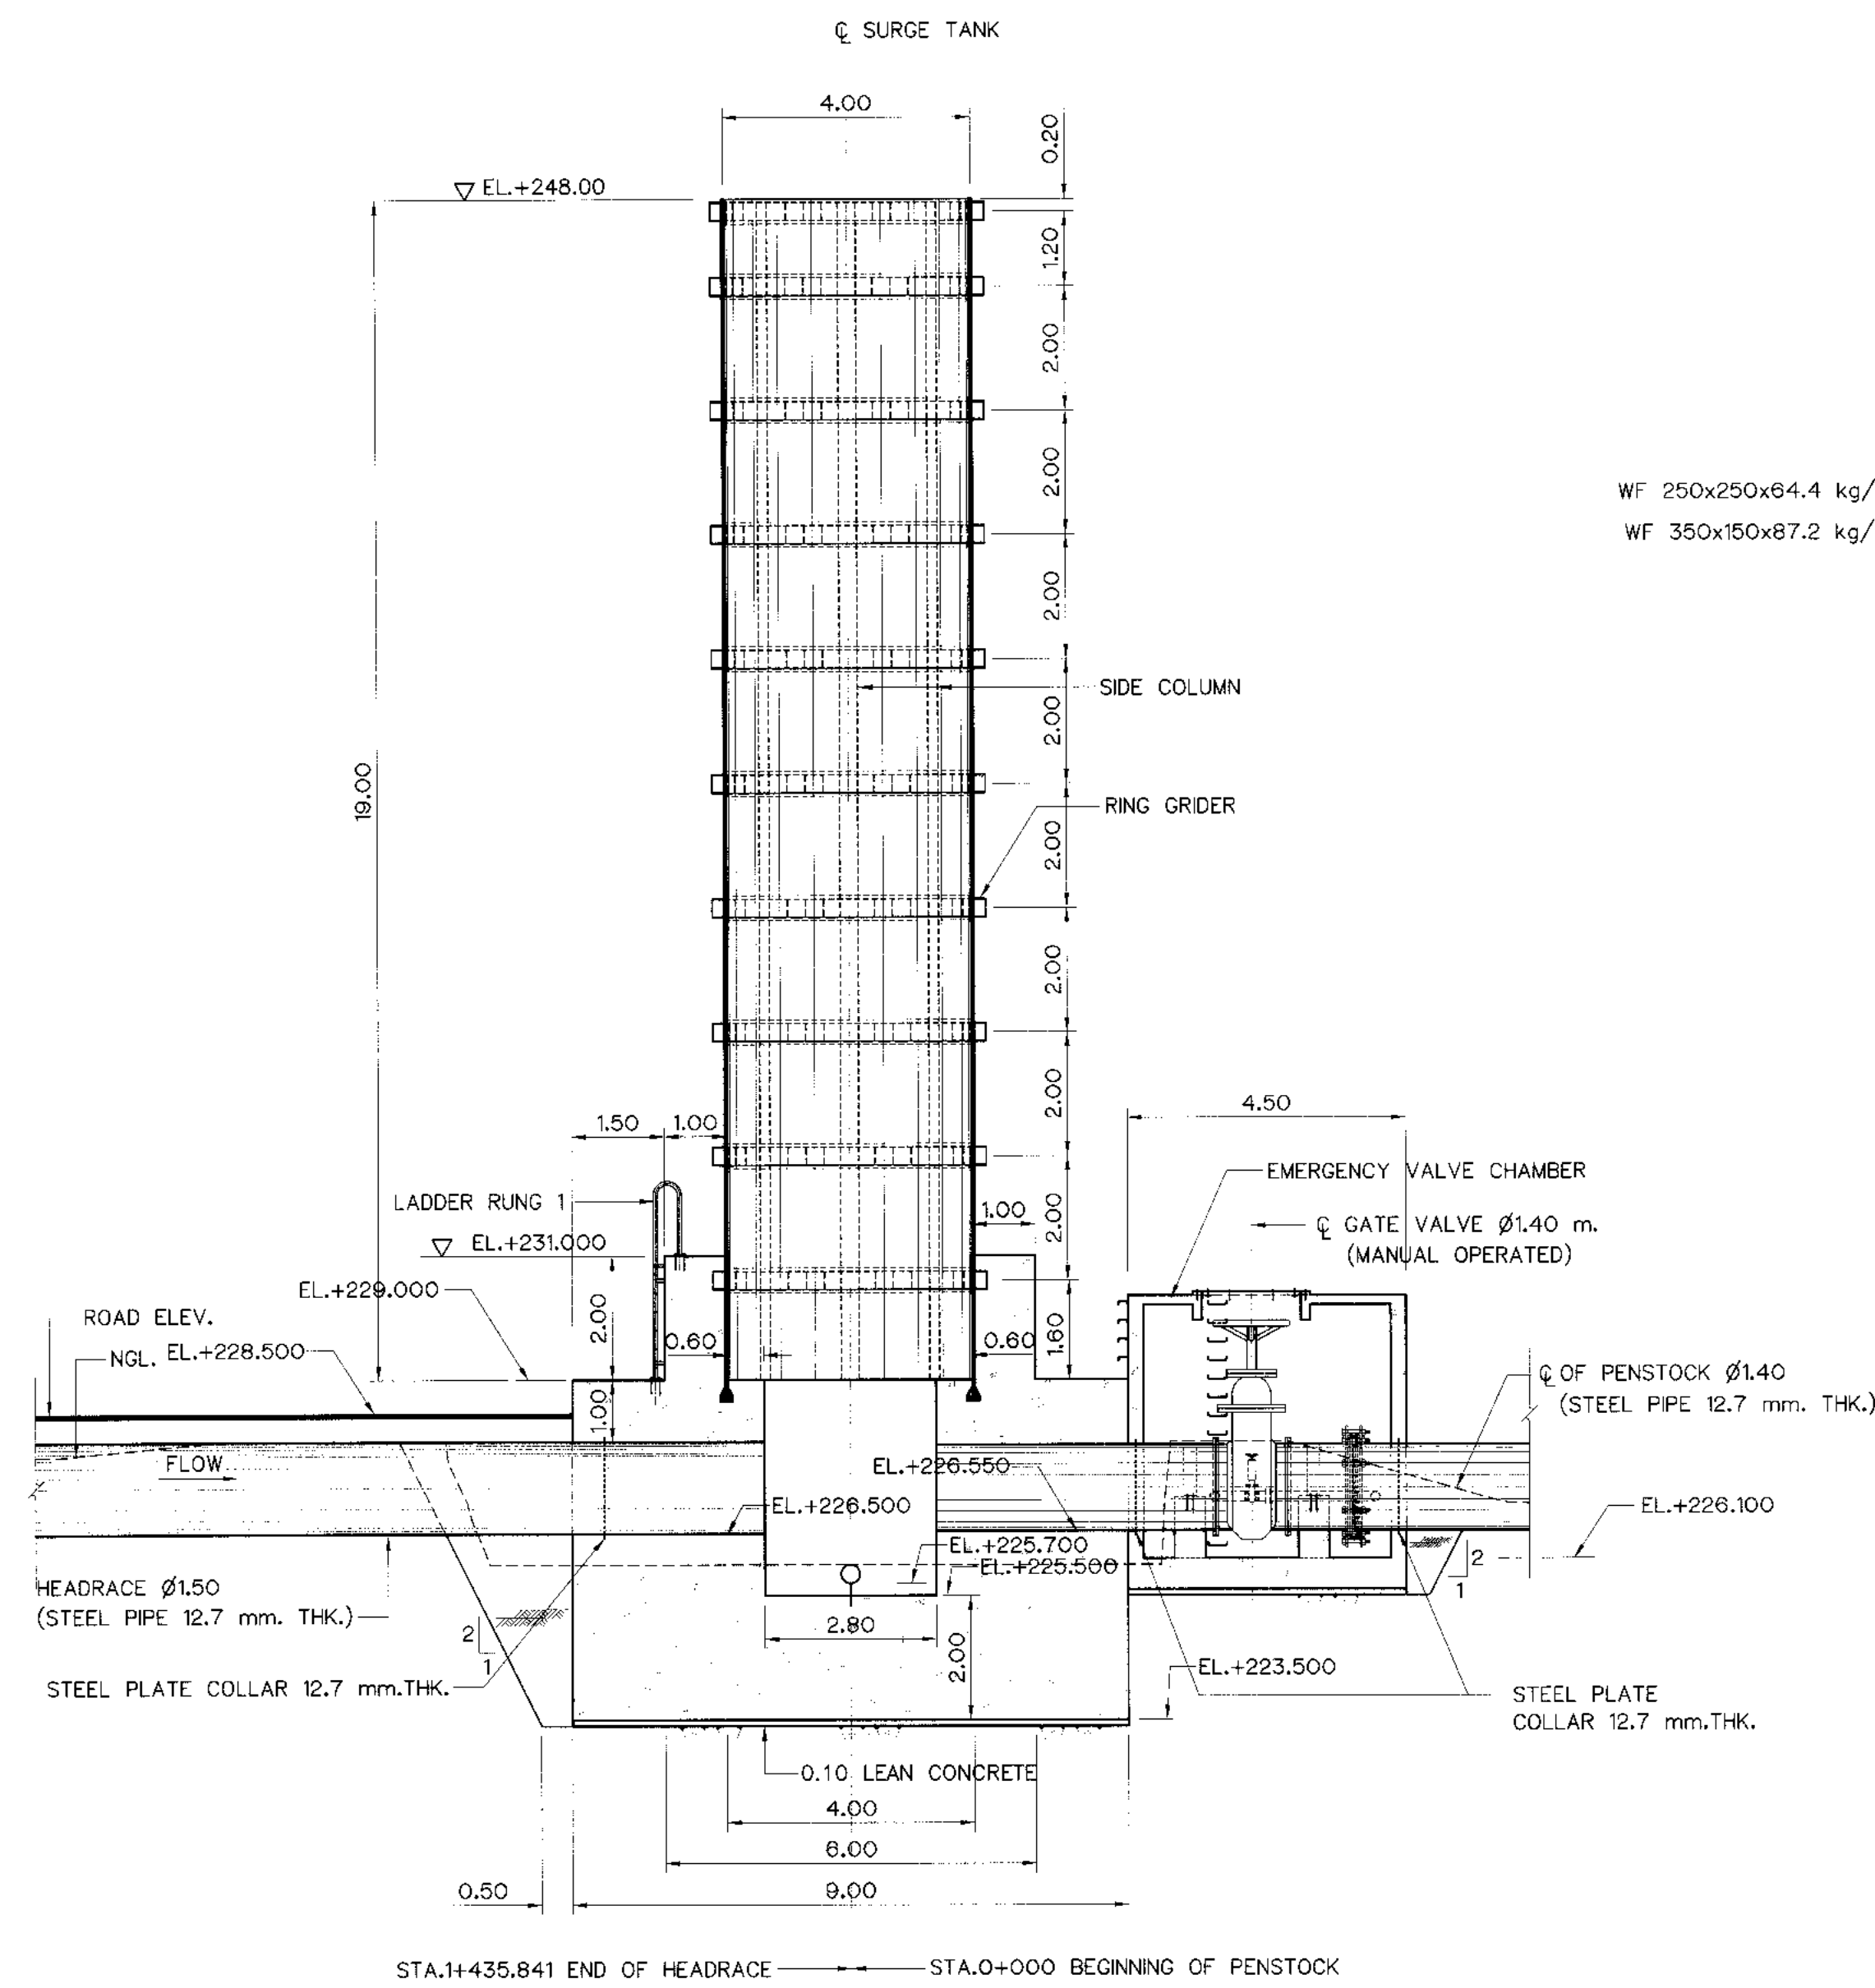


SECTION A-A
SCALE 1:100

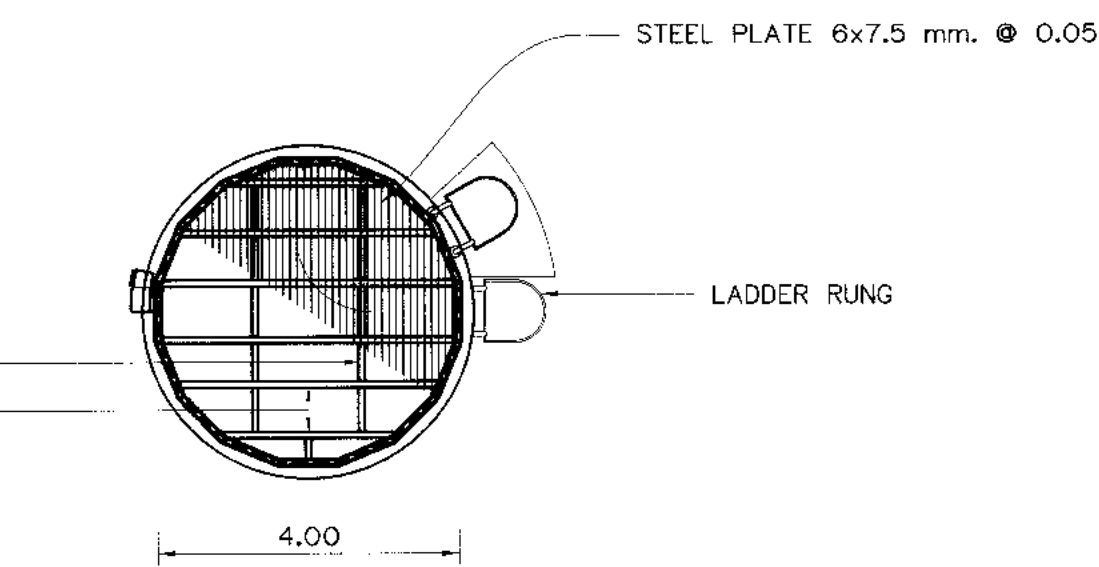

PLAN ON TOP LEVEL
SCALE 1:100

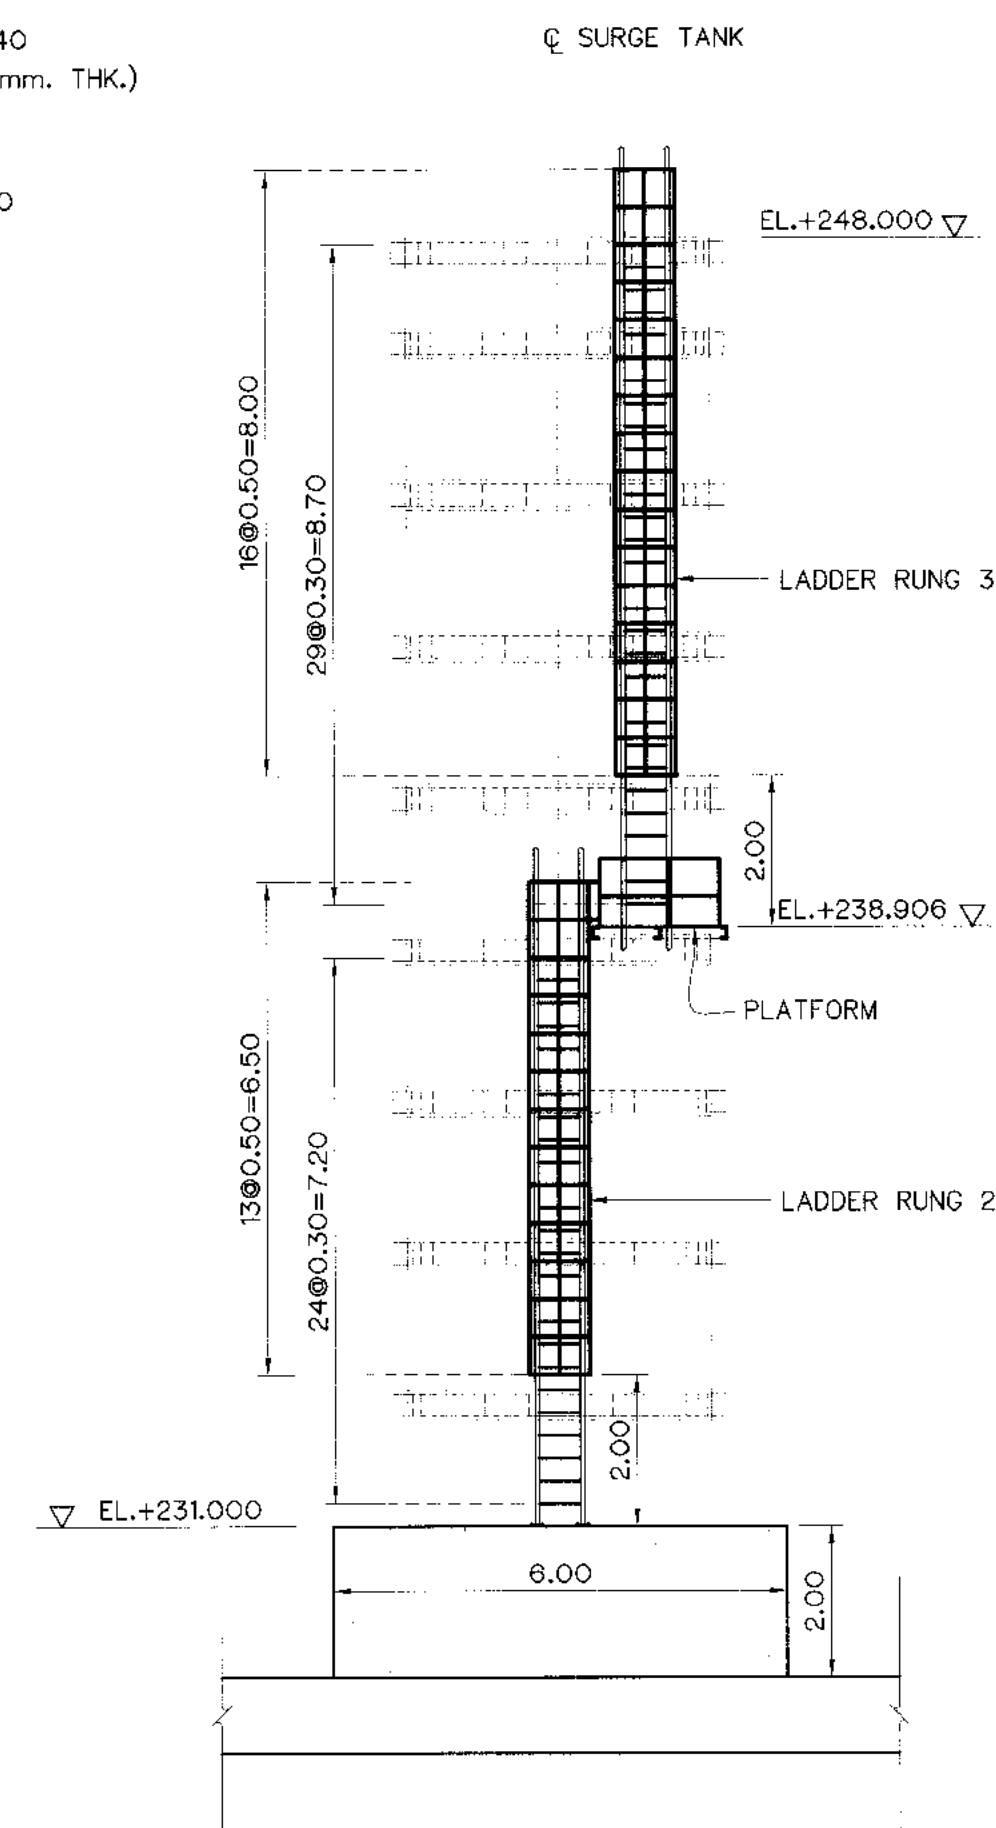

LADDER RUNG 2&3 ELEVATION
SCALE 1:100

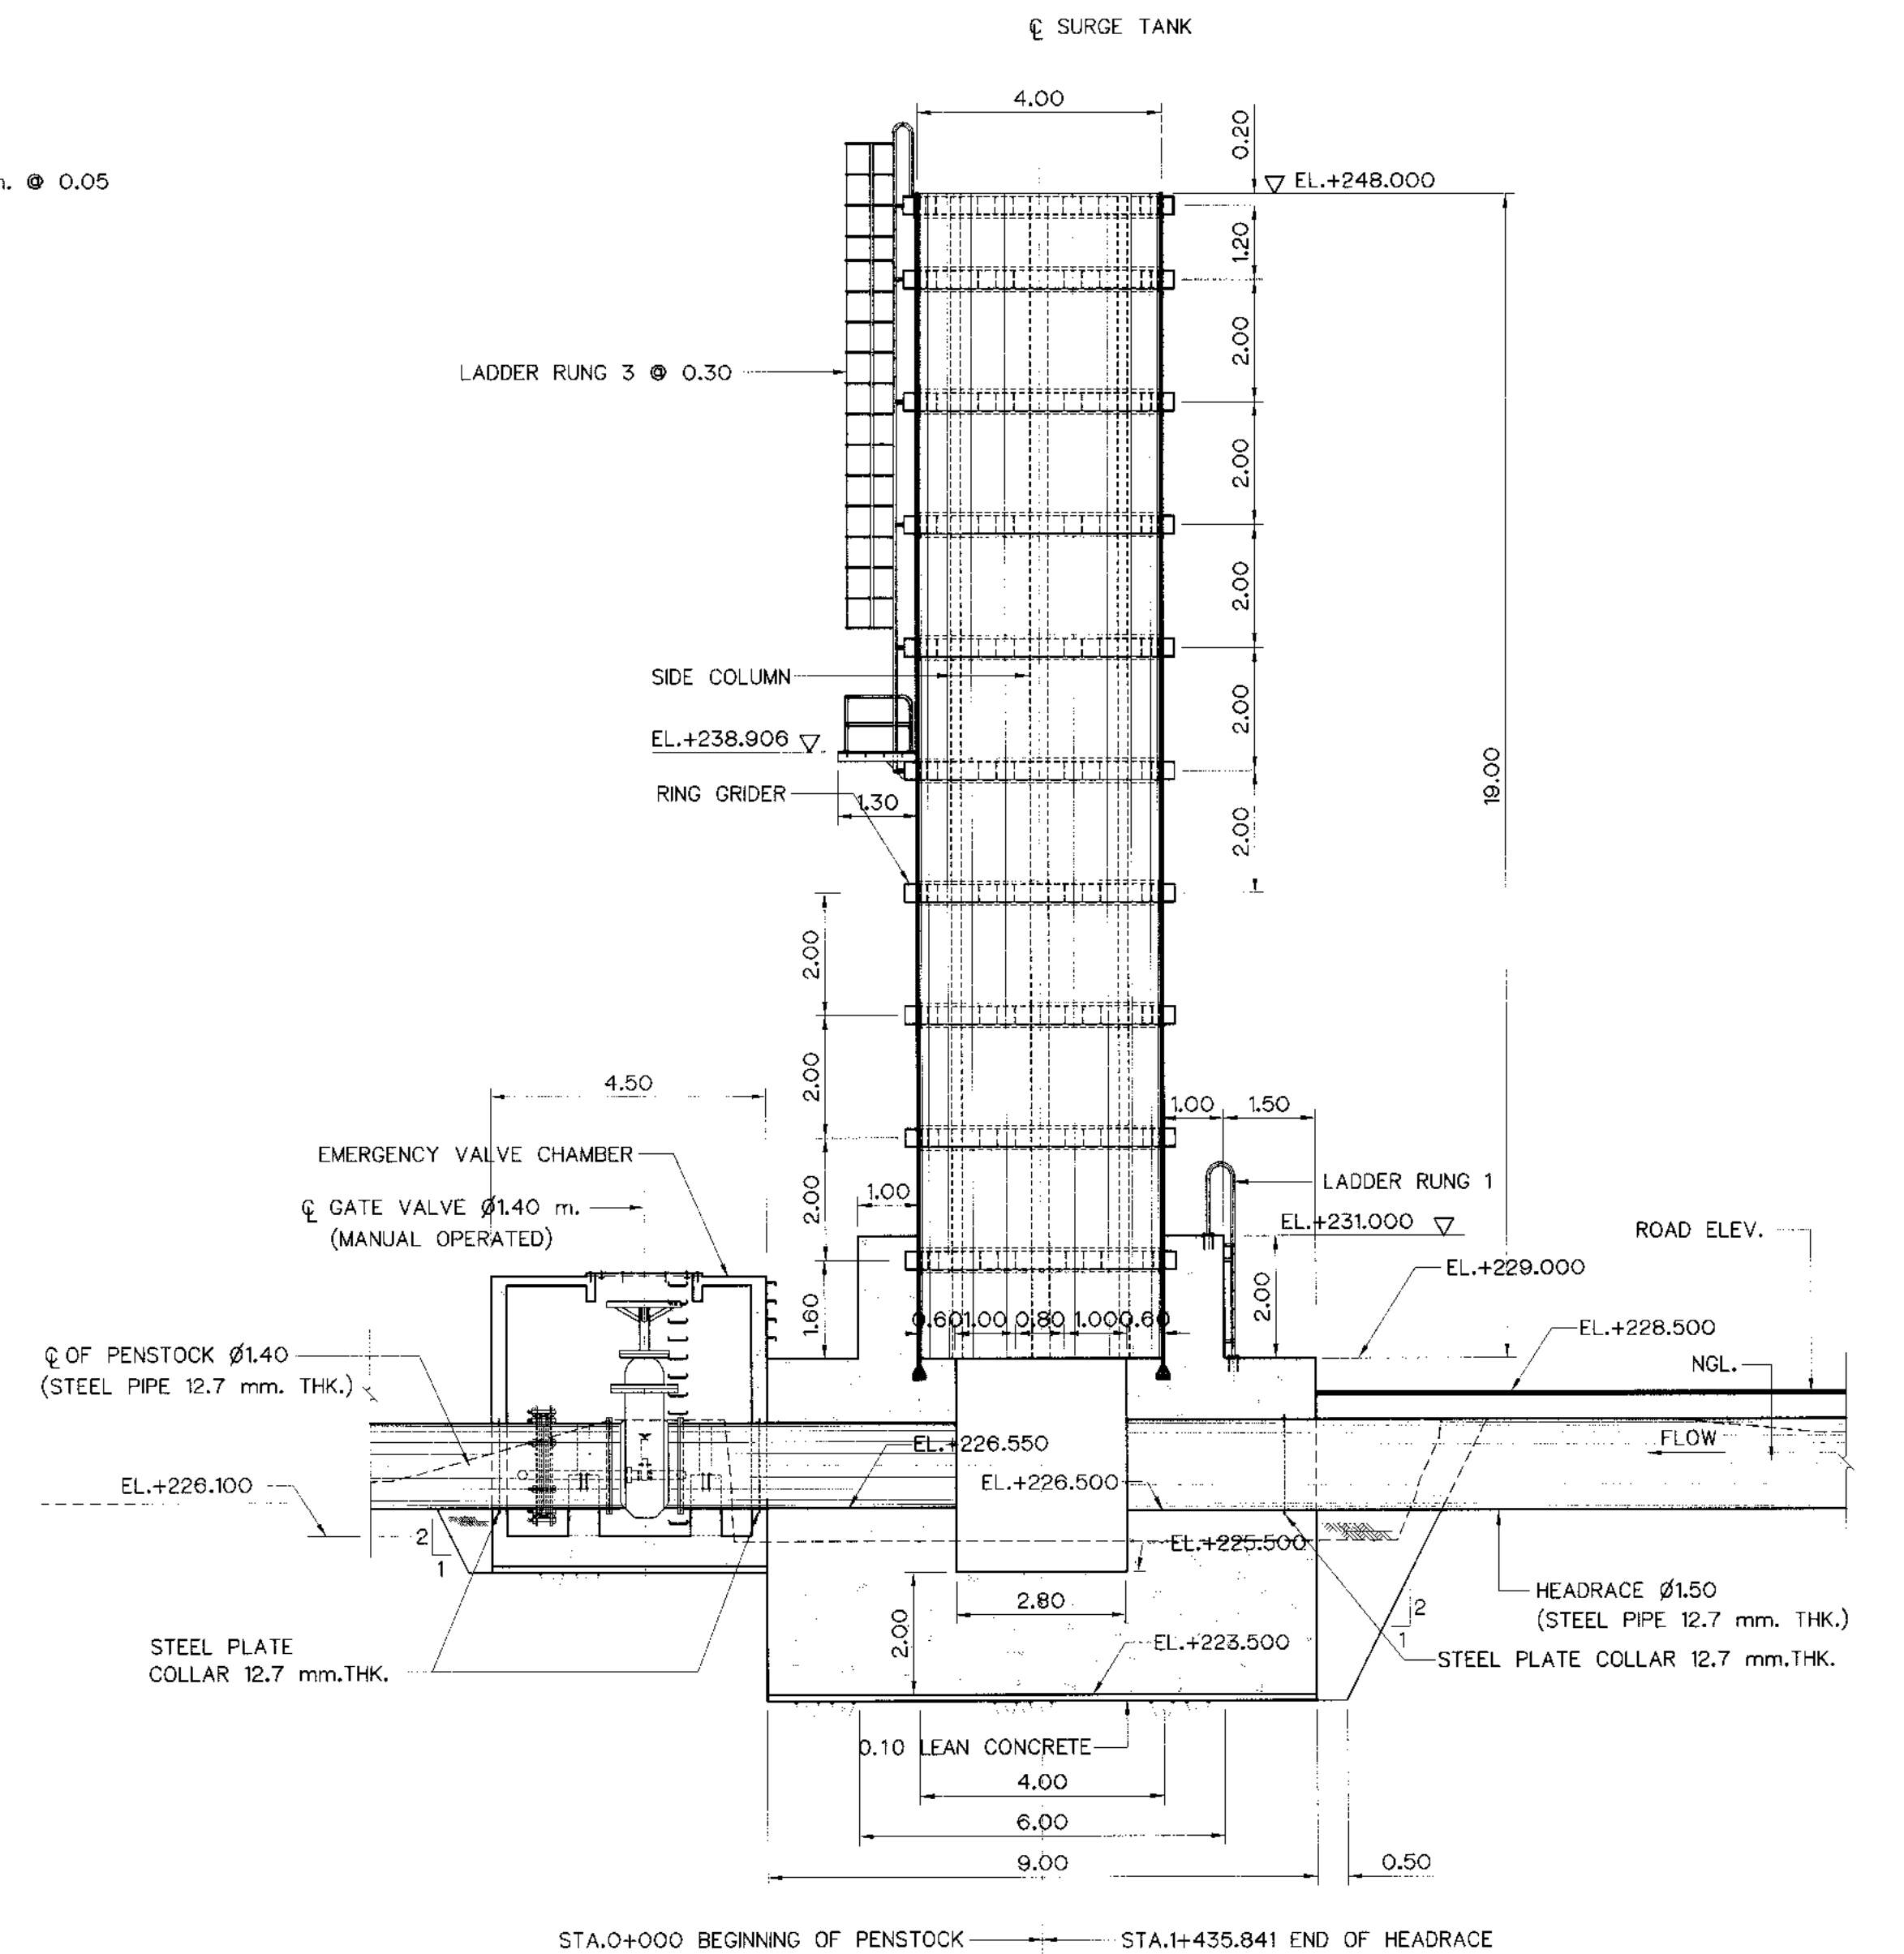


SECTION B-B
SCALE 1:100

NOTES :

- ALL DIMENSIONS AND ELEVATIONS ARE IN METERS, UNLESS OTHERWISE SHOWN.
- STEEL PIPE SHELL CONFORM TO JIS G 3101 SS34
- BASE OF CONCRETE FOUNDATION SHALL BE DETERMINED IN FIELD BY EMBEDDING TO STABLE ROCK FOUNDATION WITH A ALLOWABLE BEARING CAPACITY NOT LESS THAN 20 T/m²
- CORROSION PROTECTION OF STEEL PIPE OR GUARDRAIL IS WARNED TO STRICTLY FOLLOW GALVANIZE SPECIFICATION
- STEEL TANK , GIRDER AND STIFFENER SHALL CONFORM TO JIS G 3101 SS34

REFERENCE DRAWING :

- | | |
|-------------------------------|-----------|
| 1. SURGE TANK GENERAL LAY-OUT | KLP-ST-01 |
| 2. LADDER RUNG DETAILS | KLP-ST-03 |
| 3. PLATFORM DETAILS | KLP-ST-04 |
| 4. RING GRIDER AND HANDRAIL | KLP-ST-05 |

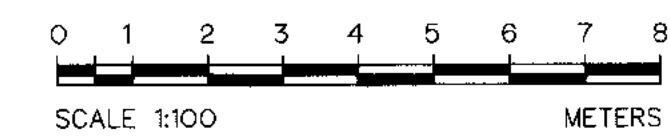

3				
2				
1				
NO.	DATE	REVISIONS	CHECKED	APPROVED
CONSULTANTS			DEDE	

KINGDOM OF THAILAND Department of Alternative Energy Development and Efficiency MINISTRY OF ENERGY	
KLONG LAM PLOK HYDROPOWER PROJECT	
CIVIL WORKS AND TRANSMISSION LINE SURGE TANK SECTIONS	
DESIGNED <i>[Signature]</i> 28.29074 DRAWN <i>[Signature]</i> CHECKED <i>[Signature]</i> 28.6226 PROJECT MANAGER	REVIEWED <i>[Signature]</i> SUBMITTED <i>[Signature]</i> RECOMMENDED <i>[Signature]</i> APPROVED <i>[Signature]</i> 28.6226 DATE 08/03/2559
P&C MANAGEMENT CO.,LTD.	DRAWING NO. KLP-ST-02 SHEET NO. 49 OF 110

PLAN LADDER RUNG 1
SCALE 1:40

SECTION A-A
SCALE 1:40

DETAIL "A"

SCALE 1:25

SECTION G-G
SCALE 1:25

DETAIL "C"

SCALE 1:25

SECTION B-B
SCALE 1:40

DETAIL "B"

SCALE 1:25

SECTION H-H
SCALE 1:25

PLAN LADDER RUNG 2

SCALE 1:40

SECTION C-C
SCALE 1:40

SECTION 1-1
SCALE 1:25

SECTION H1-H1
SCALE 1:25

DETAIL "D"

SCALE 1:10

DETAIL "E"

SCALE 1:10

DETAIL "F"

SCALE 1:10

PLAN LADDER RUNG 3
SCALE 1:40

SECTION E-E
SCALE 1:40


SECTION F-F
SCALE 1:40

NOTE :

1. ALL DIMENSIONS AND ELEVATIONS ARE IN METERS, UNLESS OTHERWISE SHOWN
2. STEEL PIPE CONFORM TO JIS G 3101 SS34
3. CORROSION PROTECTION OF STEEL PIPE OR GUARDRAIL
IS WARNED TO STRICTLY FOLLOW GALVANIZE SPECIFICATION
4. STEEL TANK , GIRDER AND STIFFENER SHALL CONFORM TO JIS G 3101 SS34

REFERENCE DRAWING :

- | | |
|---|-----------|
| 1. SURGE TANK GENERAL LAY-OUT | KLP-ST-01 |
| 2. SURGE TANK SECTIONS | KLP-ST-02 |
| 3. SURGE TANK PLATFORM DETAILS | KLP-ST-04 |
| 4. SURGE TANK RING GRIDER
AND HANDRAIL | KLP-ST-05 |

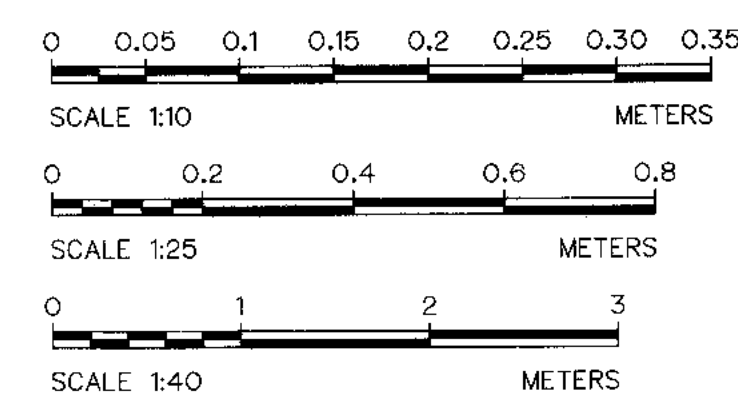

3				
2				
1				
NO.	DATE	REVISIONS	CHECKED	APPROVED
	CONSULTANTS		DEDE	


 KINGDOM OF THAILAND Department of Alternative Energy Development and Efficiency MINISTRY OF ENERGY	
KLONG LAM PLOK HYDROPOWER PROJECT	
CIVIL WORKS AND TRANSMISSION LINE	
SURGE TANK	
LADDER RUNG DETAILS	
 P&C MANAGEMENT CO.,LTD.	 Department of Alternative Energy Development and Efficiency MINISTRY OF ENERGY
DESIGNED <i>12/01/2007</i> <i>05/01</i> <i>05/01</i> <i>05/01</i>	REVIEWED <i>[Signature]</i>
DRAWN <i>[Signature]</i>	SUBMITTED <i>Chant</i>
CHECKED <i>05/01</i> <i>05/01</i>	RECOMMENDED <i>[Signature]</i>
PROJECT MANAGER <i>OK</i>	APPROVED <i>P. Hongsakul</i>
DATE <i>08/03/2559</i>	DRAWING NO. KLP-ST-03
SHEET NO. 50	OF 110



1. ALL DIMENSIONS AND ELEVATIONS ARE IN METERS, UNLESS OTHERWISE SHOWN
2. STEEL PIPE CONFORM TO JIS G 3101 SS34
3. CORROSION PROTECTION OF STEEL PIPE OR GUARDRAIL IS WARNED TO STRICTLY FOLLOW GALVANIZE SPECIFICATION
4. STEEL TANK , GIRDER AND STIFFENEL SHALL CONFORM TO JIS G 3101 SS34




1. SURGE TANK GENERAL LAY-OUT	KLP-ST-01
2. SURGE TANK SECTIONS	KLP-ST-02
3. SURGE TANK LADDER RUNG DETAILS	KLP-ST-03
4. SURGE TANK RING GRIDER AND HANDRAIL	KLP-ST-05

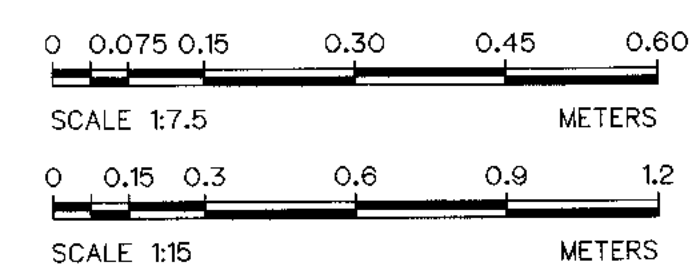


3				
2				
1				
NO.	DATE	REVISIONS	CHECKED	APPROVED
	CONSULTANTS		DEDE	


 KINGDOM OF THAILAND Department of Alternative Energy Development and Efficiency MINISTRY OF ENERGY	
KLONG LAM PLOK HYDROPOWER PROJECT	
CIVIL WORKS AND TRANSMISSION LINE SURGE TANK PLATFORM DETAILS	
 P&C MANAGEMENT CO.,LTD.	 Department of Alternative Energy Development and Efficiency MINISTRY OF ENERGY
DESIGNED <i>[Signature]</i> <i>21.29074</i> <i>0.9</i> <i>281.6226</i>	REVIEWED <i>[Signature]</i>
DRAWN <i>[Signature]</i>	SUBMITTED <i>Chant</i>
CHECKED <i>[Signature]</i> <i>281.6226</i>	RECOMMENDED <i>[Signature]</i>
PROJECT MANAGER <i>[Signature]</i> <i>08/03/2559</i>	APPROVED <i>P.Hang</i>
DATE	DRAWING NO. KLP-ST-04
SHEET NO. 51 OF 110	

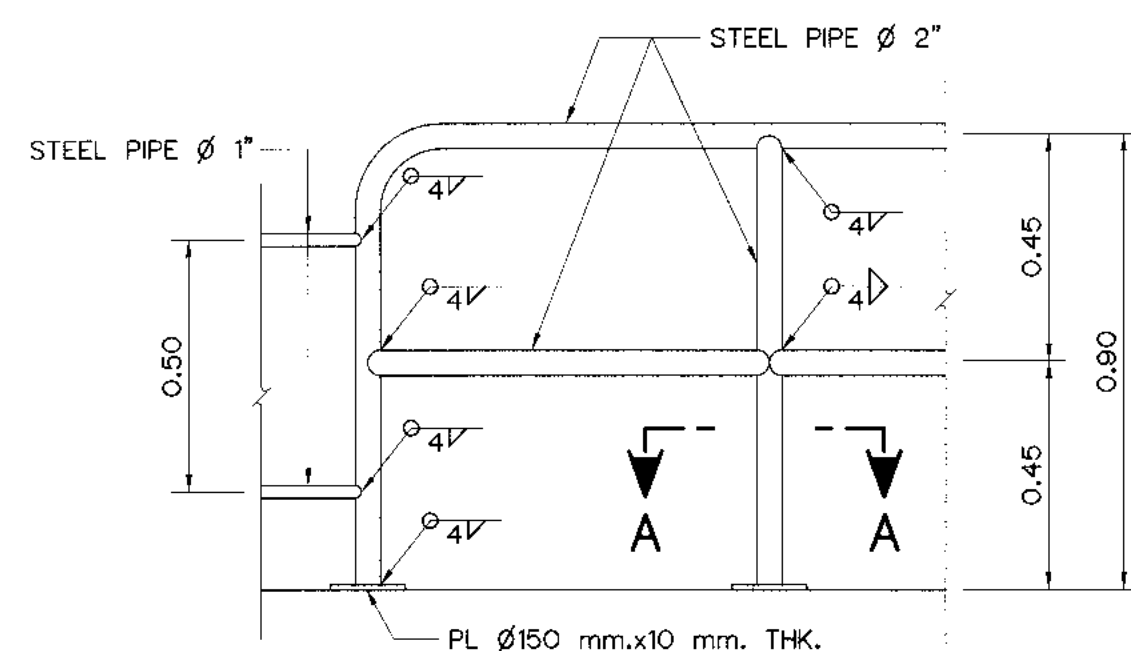


DETAIL OF HANDRAIL
SCALE 1:15

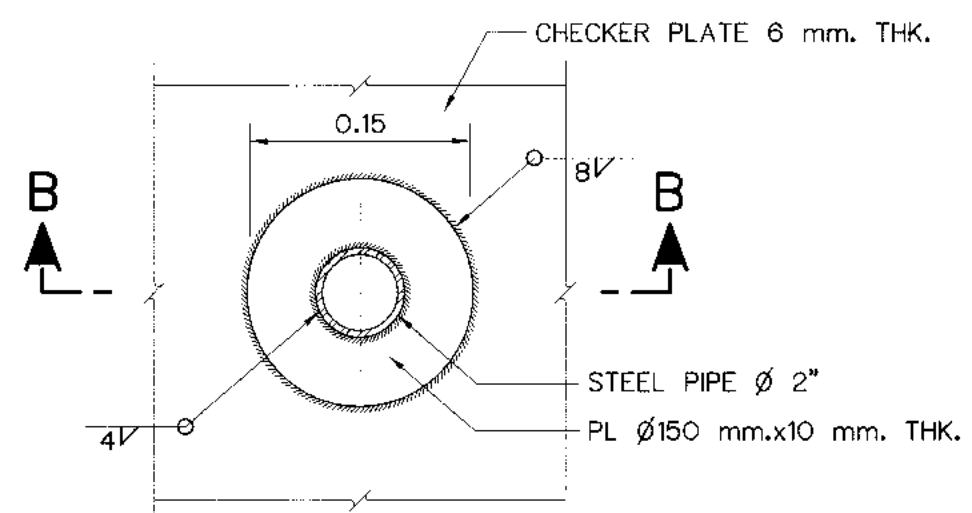


SECTION A-A
SCALE 1:5

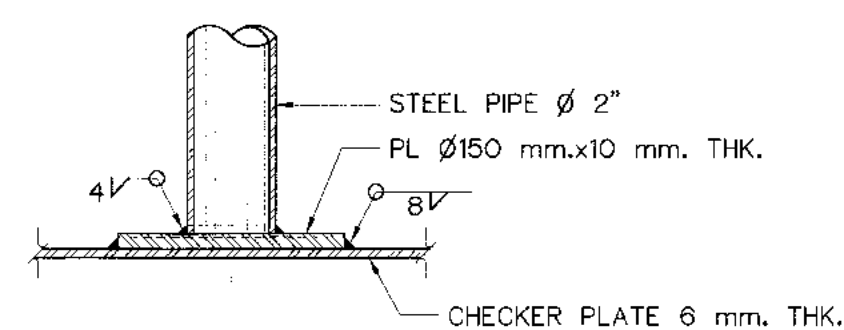


SECTION B-B
SCALE 1:5

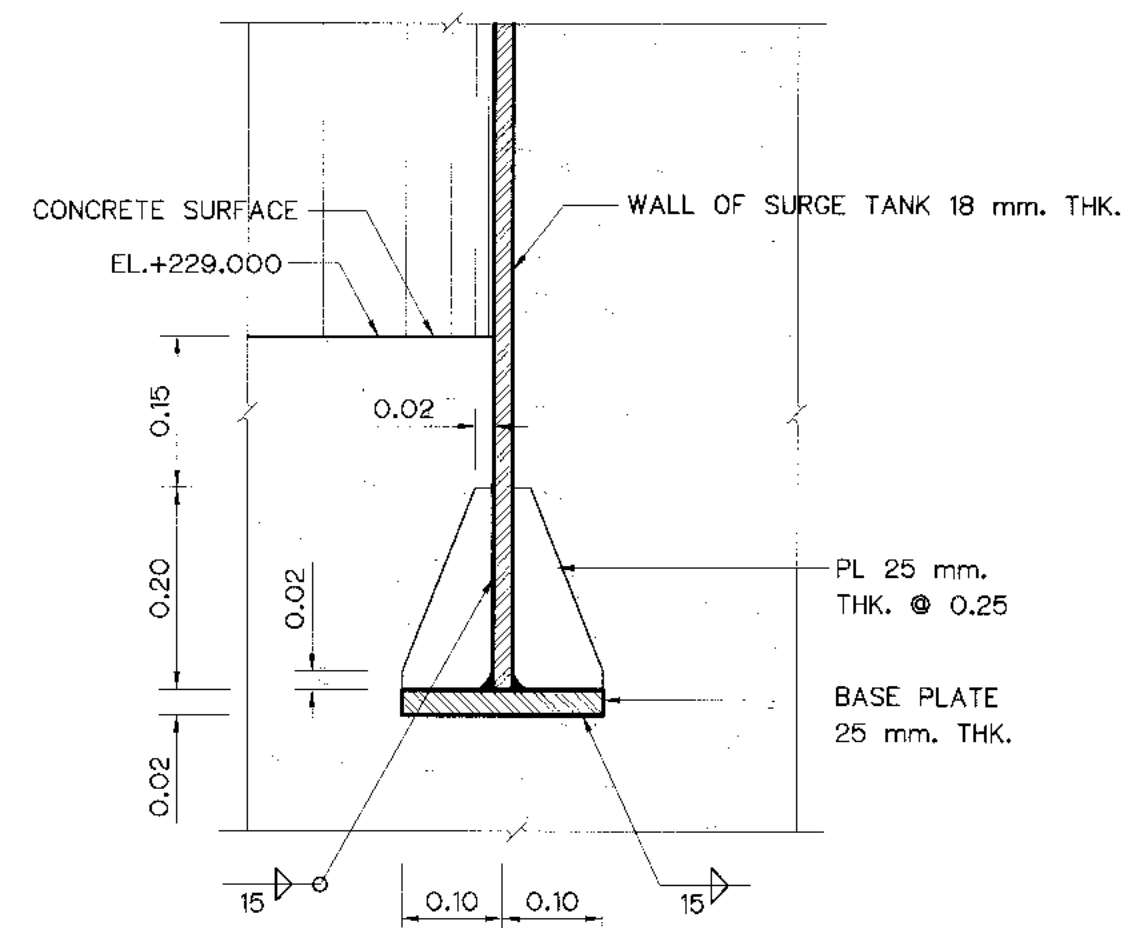


DETAIL "A"
SCALE 1:10

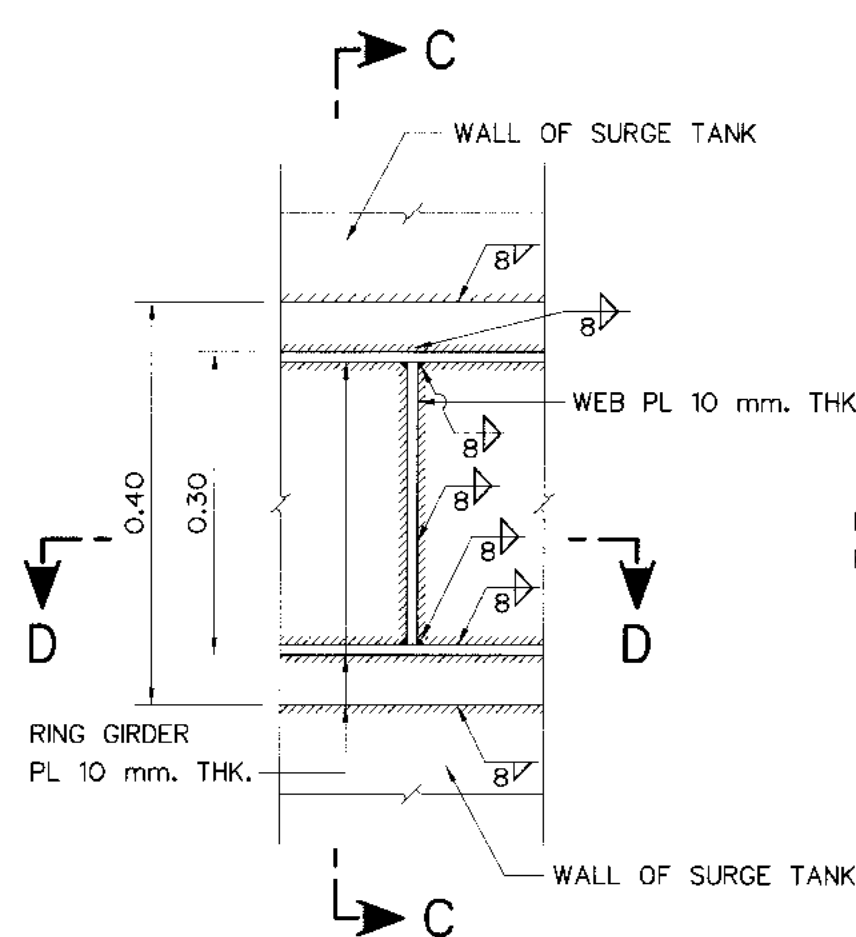


SIDE VIEW OF RING GIRDER
SCALE 1:7.5

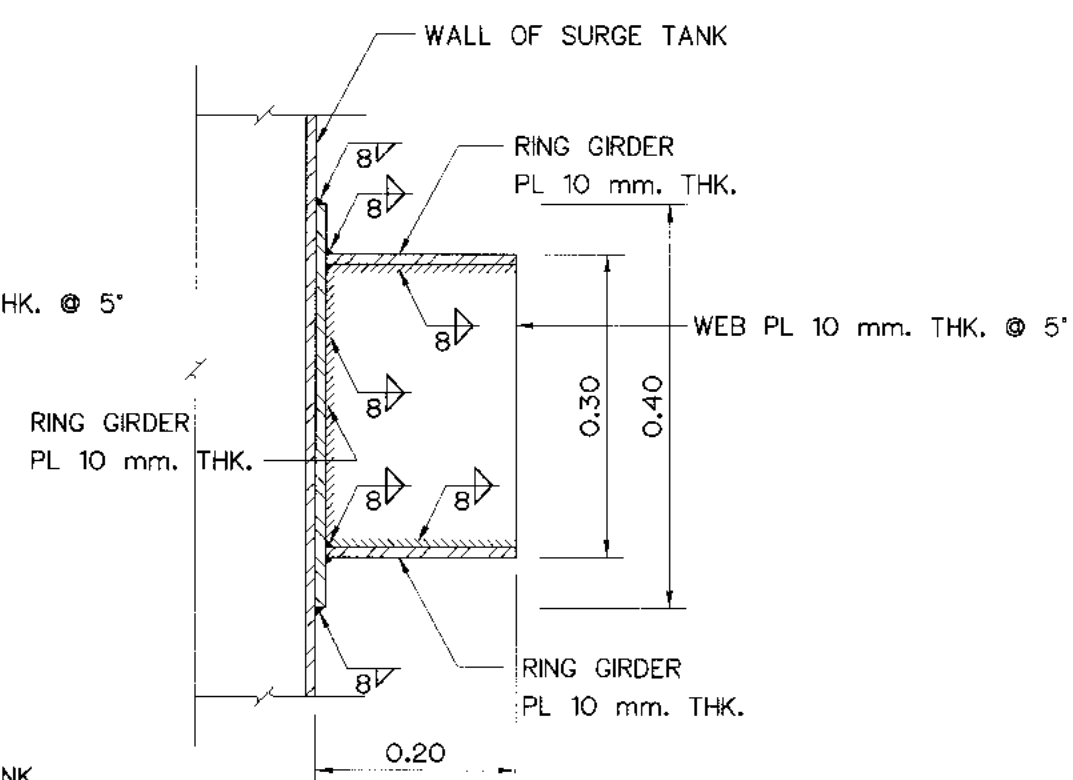


SECTION C-C
SCALE 1:7.5

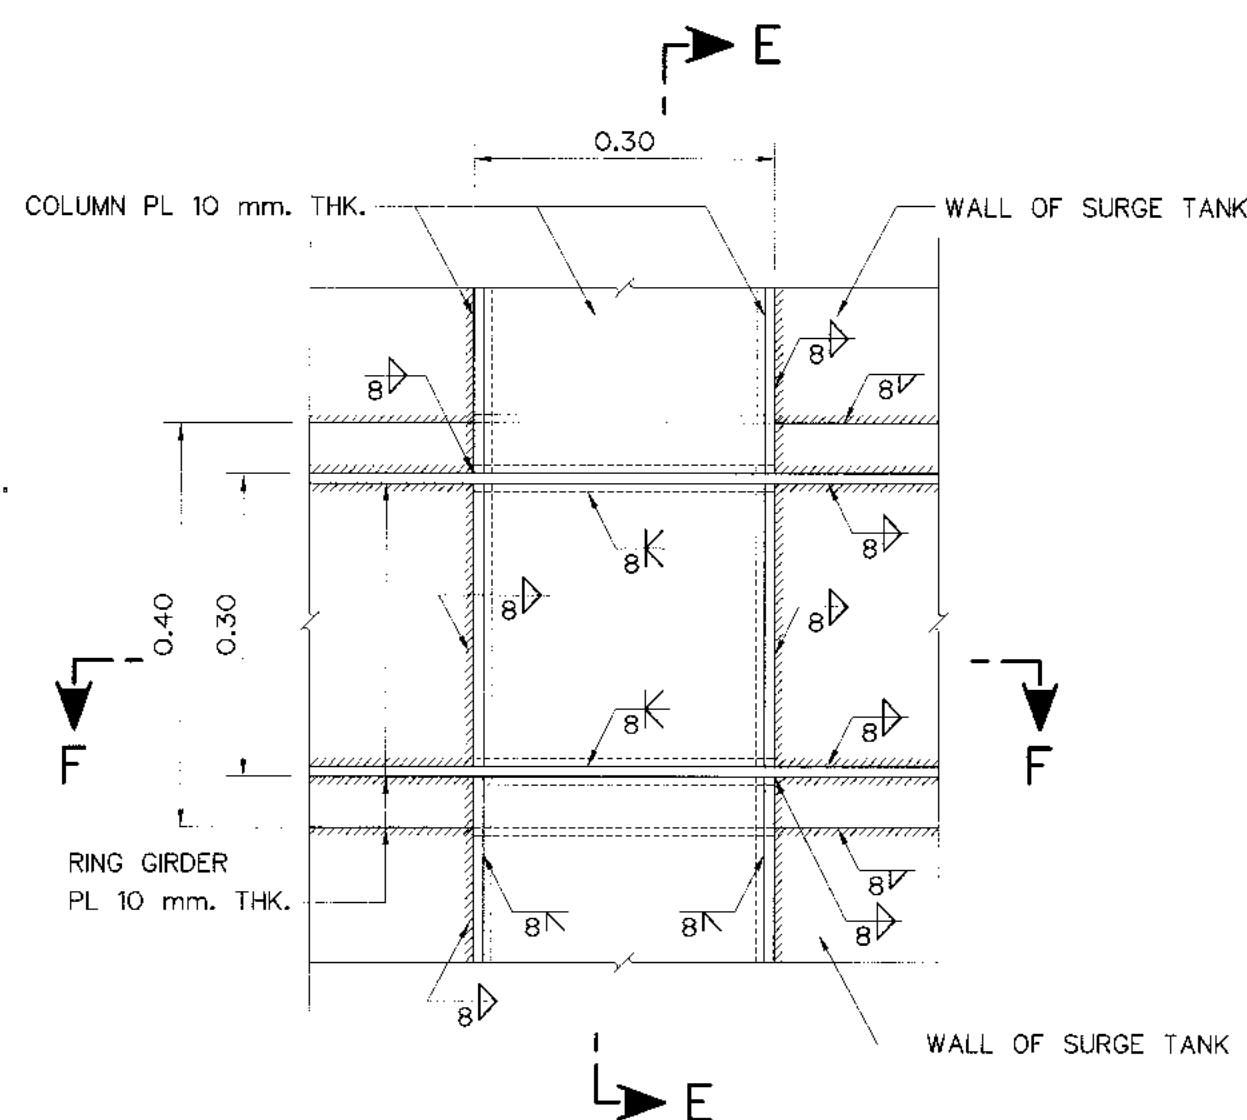


SIDE VIEW OF COLUMN
AND RING GIRDER
SCALE 1:7.5

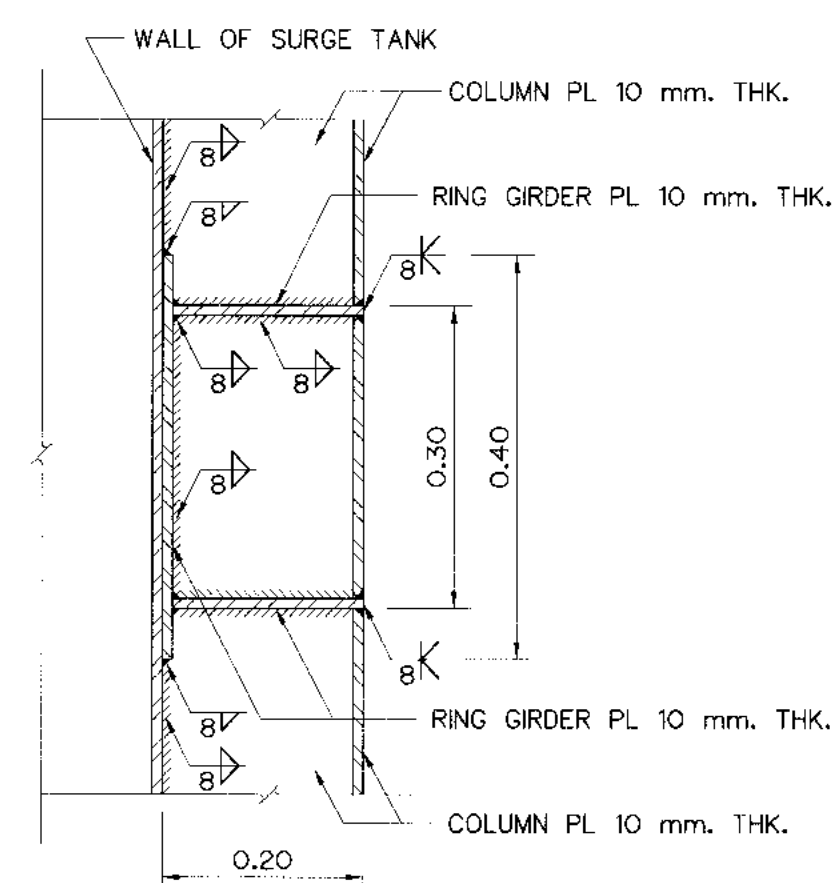

SECTION E-E
SCALE 1:7.5

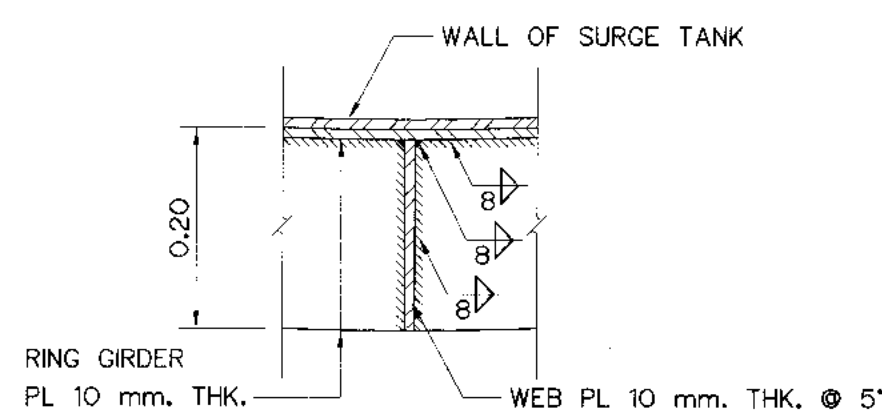

SECTION D-D
SCALE 1:7.5

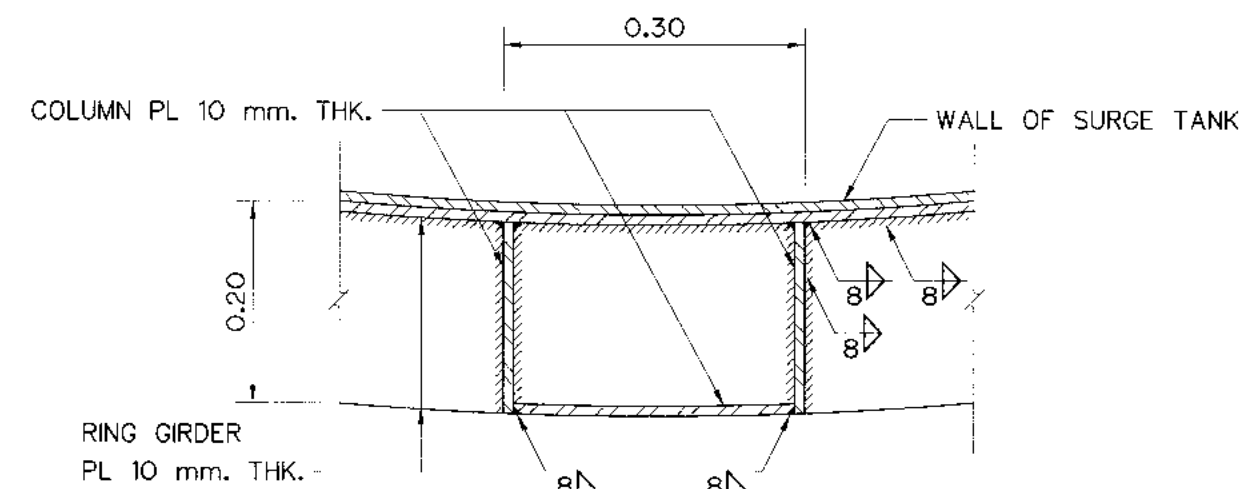

SECTION F-F
SCALE 1:7.5


RING GIRDER DETAILS

NOTE :

1. ALL DIMENSIONS AND ELEVATIONS ARE IN METERS, UNLESS OTHERWISE SHOWN
2. STEEL PIPE CONFORM TO JIS G 3101 SS34
3. CORROSION PROTECTION OF STEEL PIPE OR GUARDRAIL IS WARNED TO STRICTLY FOLLOW GALVANIZE SPECIFICATION
4. STEEL TANK , GIRDER AND STIFFENEL SHALL CONFORM TO JIS G 3101 SS34

REFERENCE DRAWING :

1. SURGE TANK GENERAL LAY-OUT KLP-ST-01
2. SURGE TANK SECTIONS KLP-ST-02

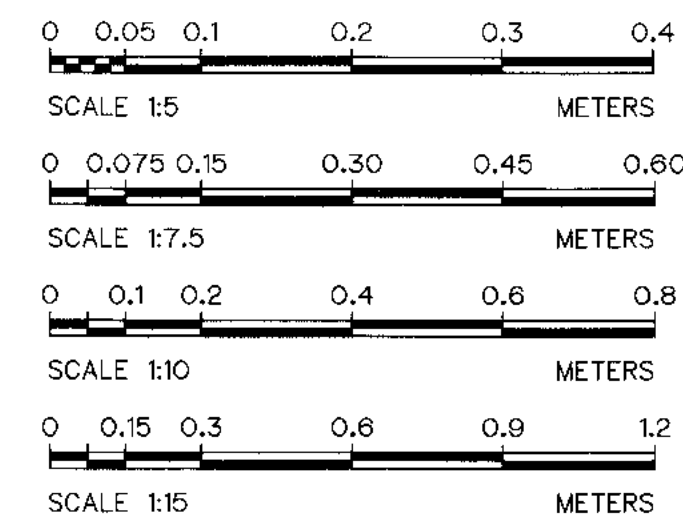




3				
2				
1				
NO.	DATE	REVISIONS	CHECKED	APPROVED

KLONG LAM PLOK HYDROPOWER PROJECT	
CIVIL WORKS AND TRANSMISSION LINE	
SURGE TANK	
RING GIRDER AND HANDRAIL	
DESIGNED <i>11/12/29074</i> 05/28/6226	REVIEWED <i>Chavit</i>
DRAWN <i>11/12/29074</i> 05/28/6226	SUBMITTED <i>Chavit</i>
CHECKED <i>05/28/6226</i>	RECOMMENDED <i>05/28/6226</i>
APPROVED <i>05/28/6226</i>	APPROVED <i>05/28/6226</i>
PROJECT MANAGER <i>08/03/2559</i>	DRAWING NO. KLP-ST-05 SHEET NO. 52 OF 110



3				
2				
1				
NO.	DATE	REVISIONS	CHECKED	APPROVED
	CONSULTANTS		DEDE	


 KINGDOM OF THAILAND Department of Alternative Energy Development and Efficiency MINISTRY OF ENERGY	
KLONG LAM PLOK HYDROPOWER PROJECT	
CIVIL WORKS AND TRANSMISSION LINE SURGE TANK REINFORCEMENT DETAILS	
 P&C MANAGEMENT CO.,LTD.	 Department of Alternative Energy Development and Efficiency MINISTRY OF ENERGY
DESIGNED <i>W</i> 28.29074 <i>85</i> 28.8226	REVIEWED <i>Chant</i>
DRAWN <i>Jim M</i>	SUBMITTED <i>Chant</i>
CHECKED <i>28.8226</i> 28.8226	APPROVED <i>P. Harnell</i>
<i>PR</i> PROJECT MANAGER	09/03/2559 DATE
KLP-ST-06	SHEET NO. 53 OF 110

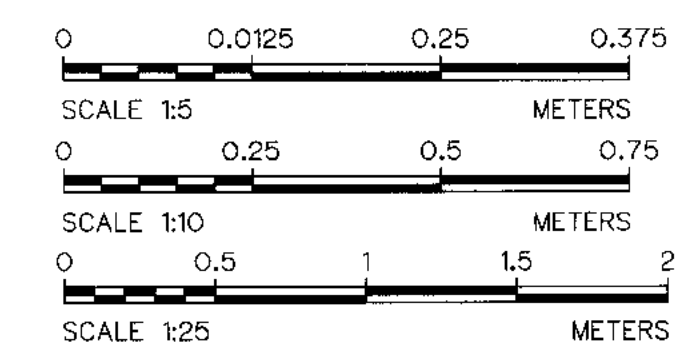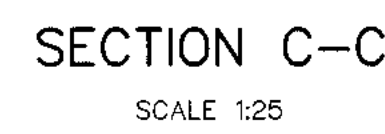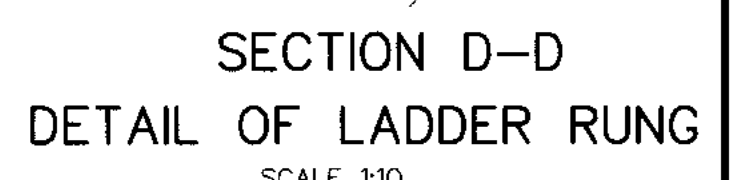


1. SURGE TANK, GENERAL LAY-OUT KLP-ST-01

3				
2				
1				
NO.	DATE	REVISIONS	CHECKED	APPROVED
	CONSULTANTS		DEDE	


 KINGDOM OF THAILAND Department of Alternative Energy Development and Efficiency MINISTRY OF ENERGY	
KLONG LAM PLOK HYDROPOWER PROJECT	
CIVIL WORKS AND TRANSMISSION LINE	
SURGE TANK	
EMERGENCY VALVE CHAMBER PLAN SECTIONS AND DETAILS	
 P&C MANAGEMENT CO.,LTD.	 Department of Alternative Energy Development and Efficiency MINISTRY OF ENERGY
DESIGNED <i>[Signature]</i> 281.29074 281.6226	REVISED <i>[Signature]</i>
DRAWN <i>[Signature]</i>	SUBMITTED <i>Chuan</i>
CHECKED <i>[Signature]</i> 281.6226	RECOMMENDED <i>[Signature]</i>
<i>OL</i> PROJECT MANAGER	APPROVED <i>P. Hunsell</i>
OR 08/01/2559	DRAWING NO. KLP-ST-07
DATE	SHEET NO. 54 OF 110

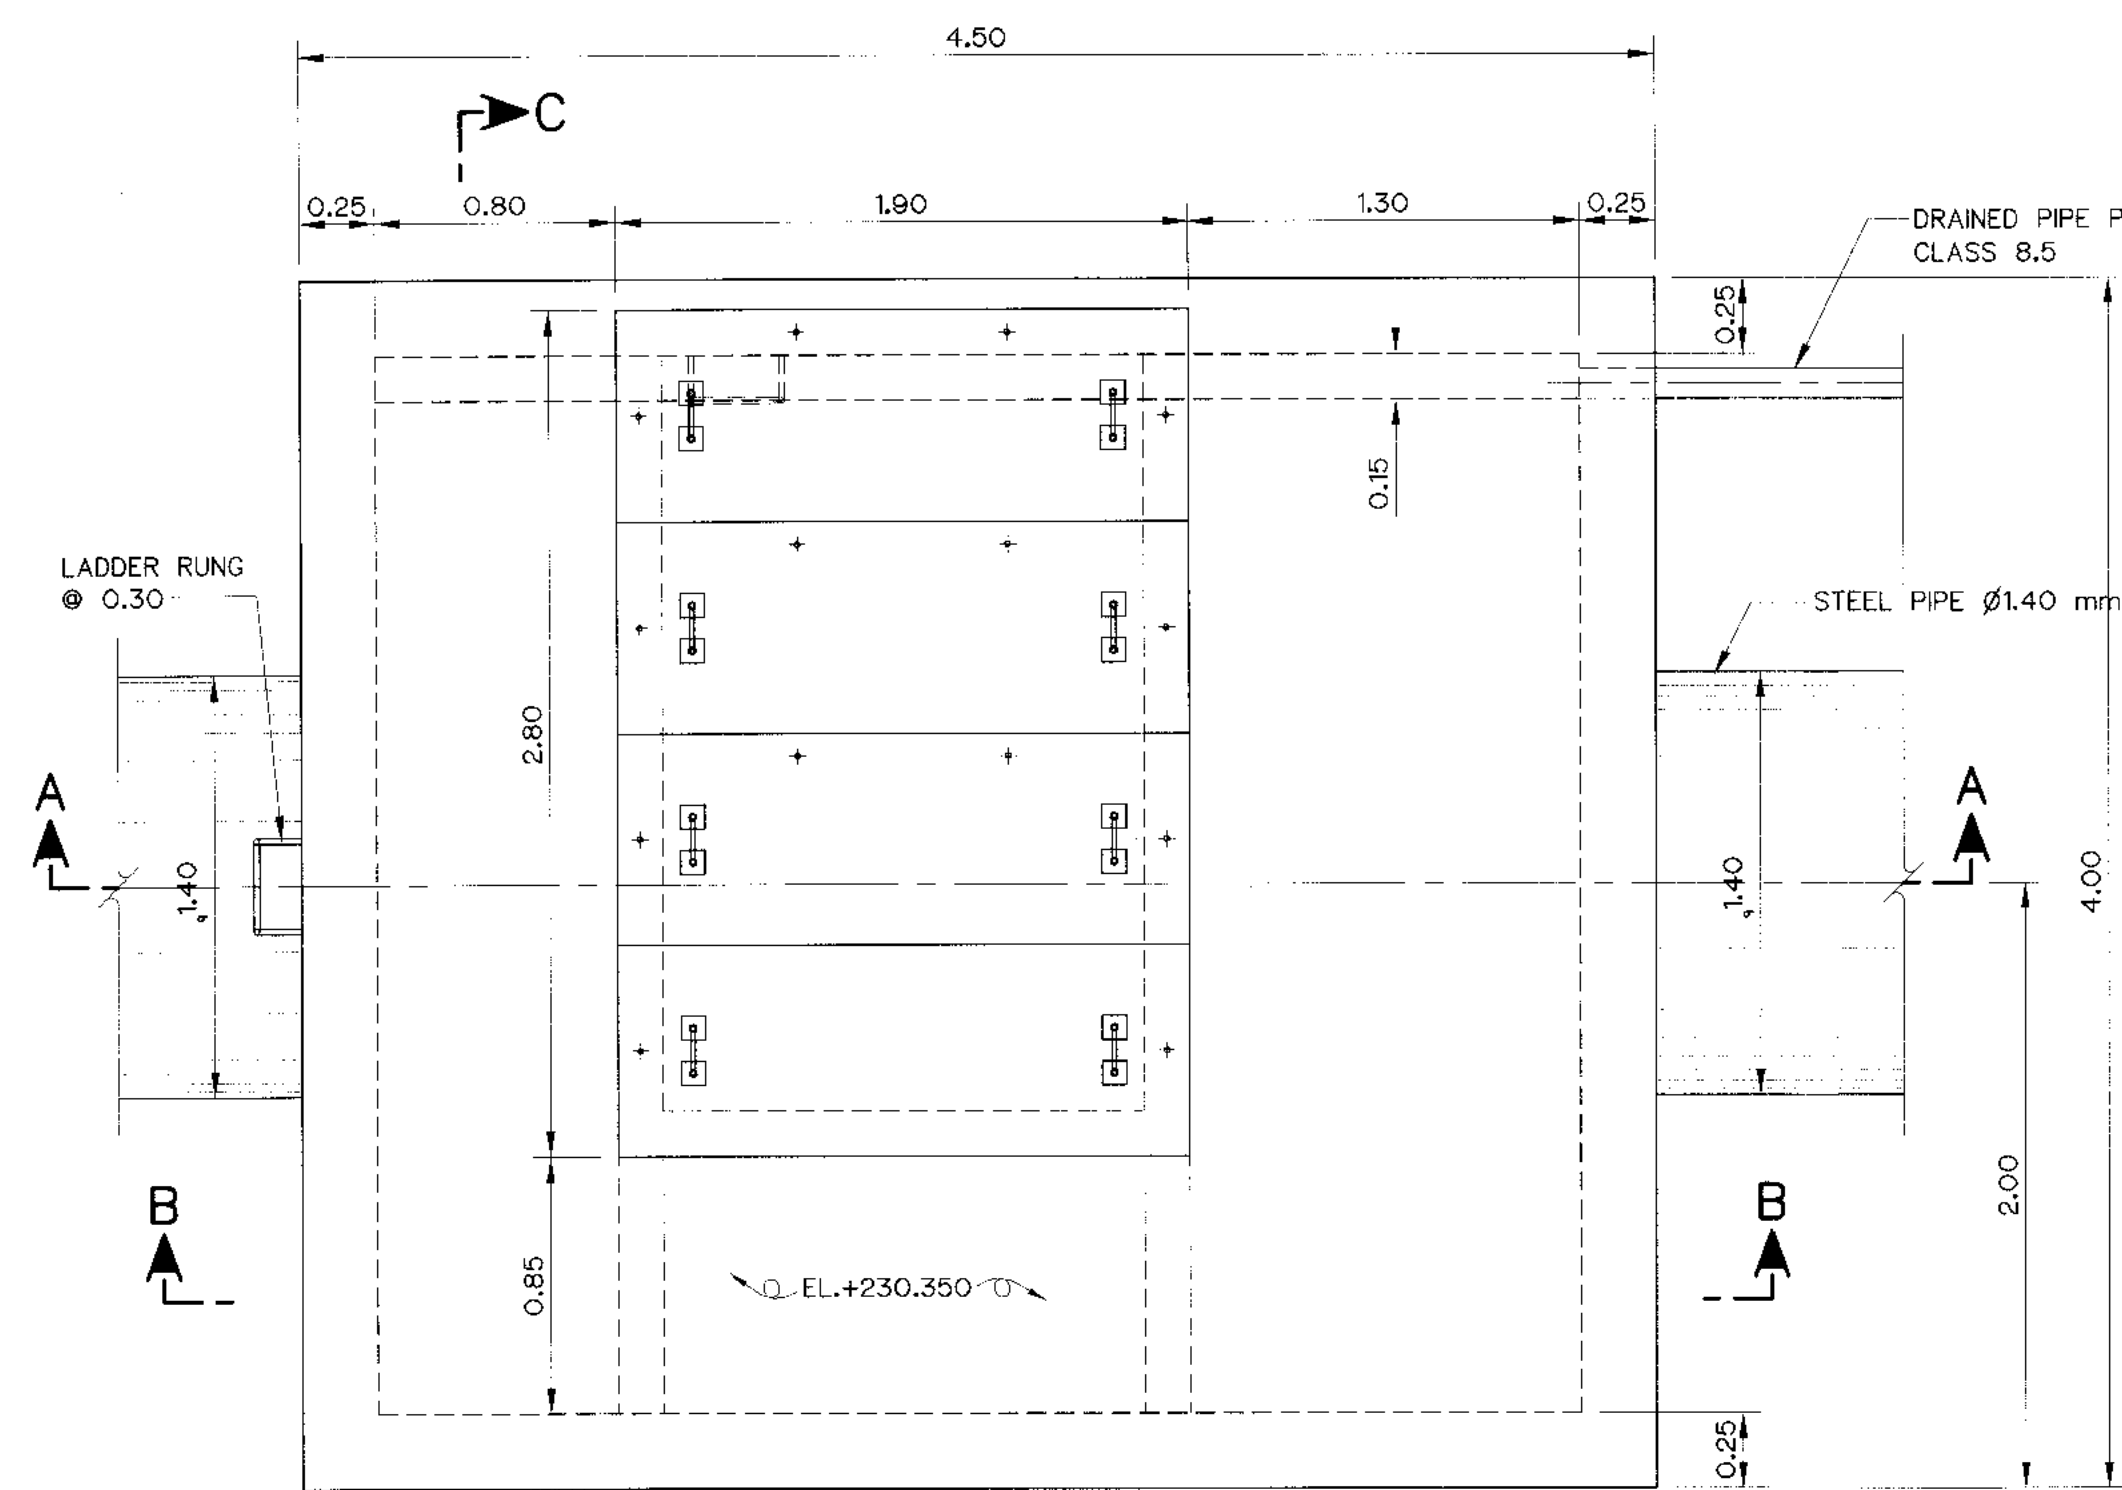


PLAN
SCALE 1:25

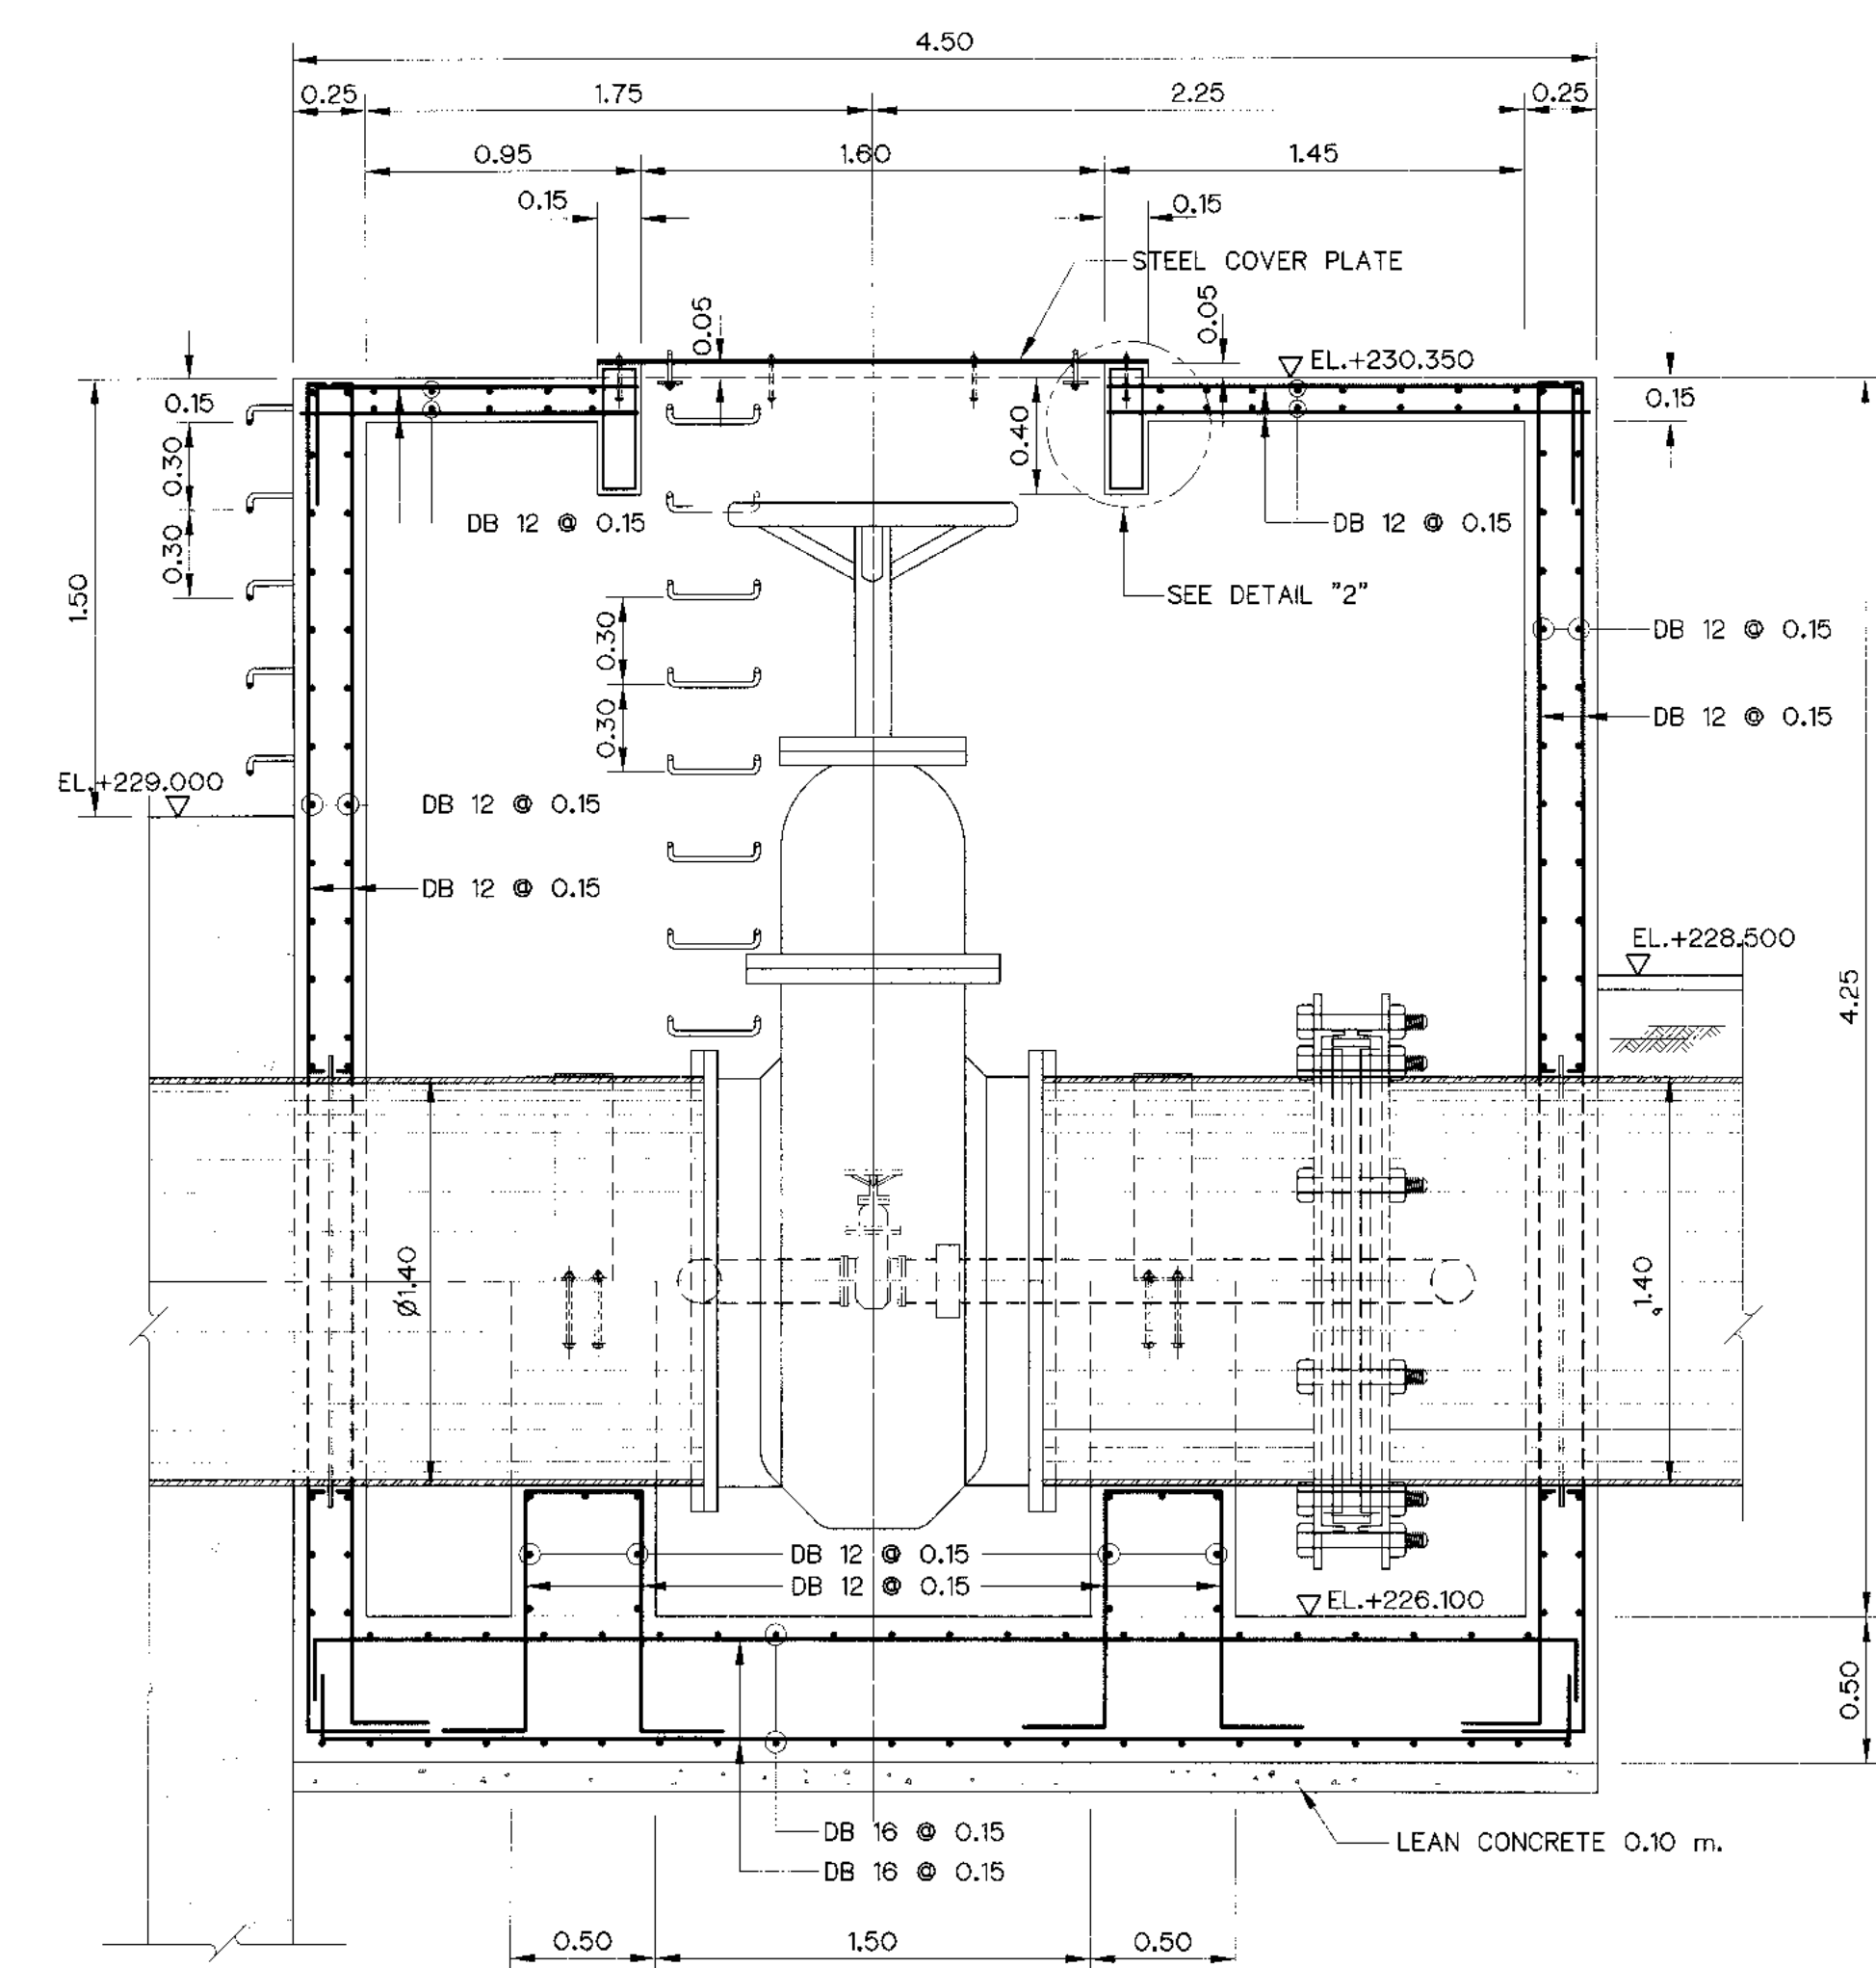


SECTION A-A
SCALE 1:25

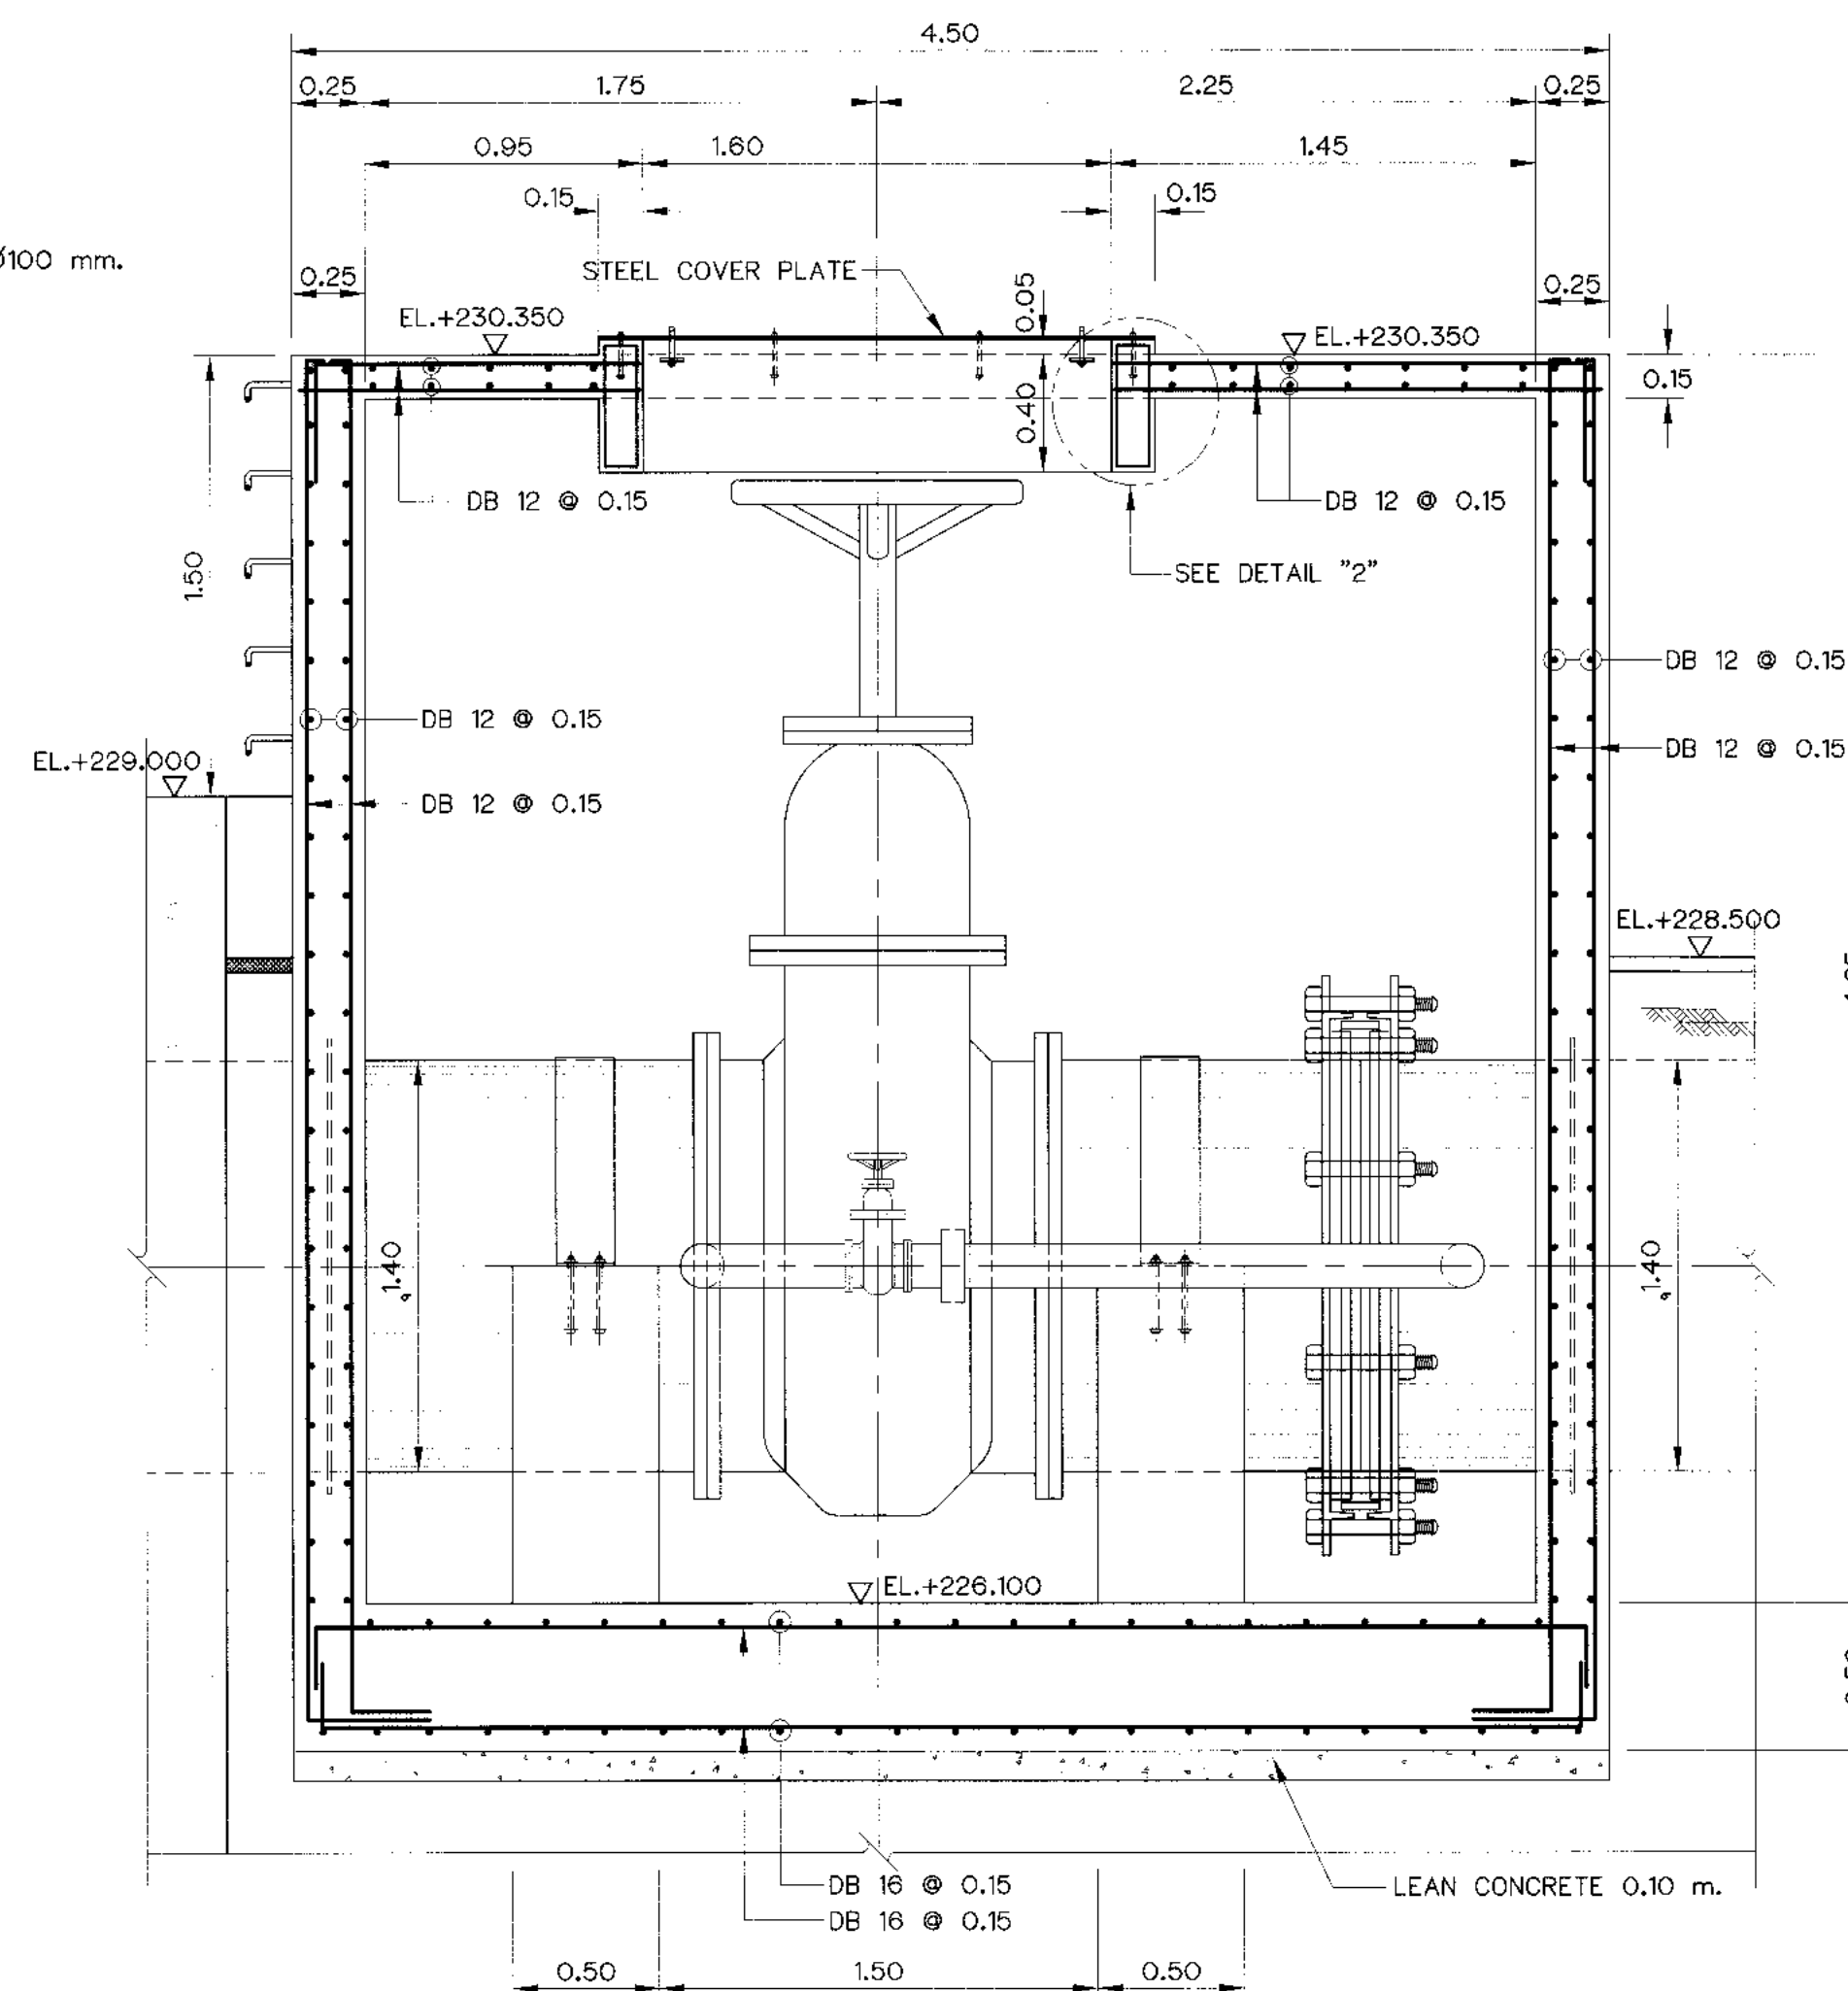


SECTION B-B
SCALE 1:25

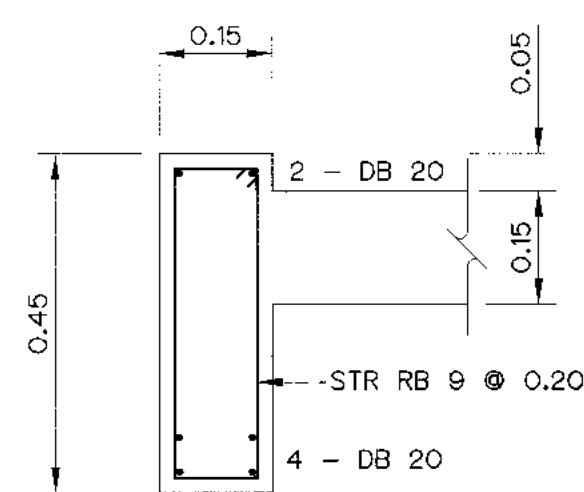

DETAIL "2"
SCALE 1:10

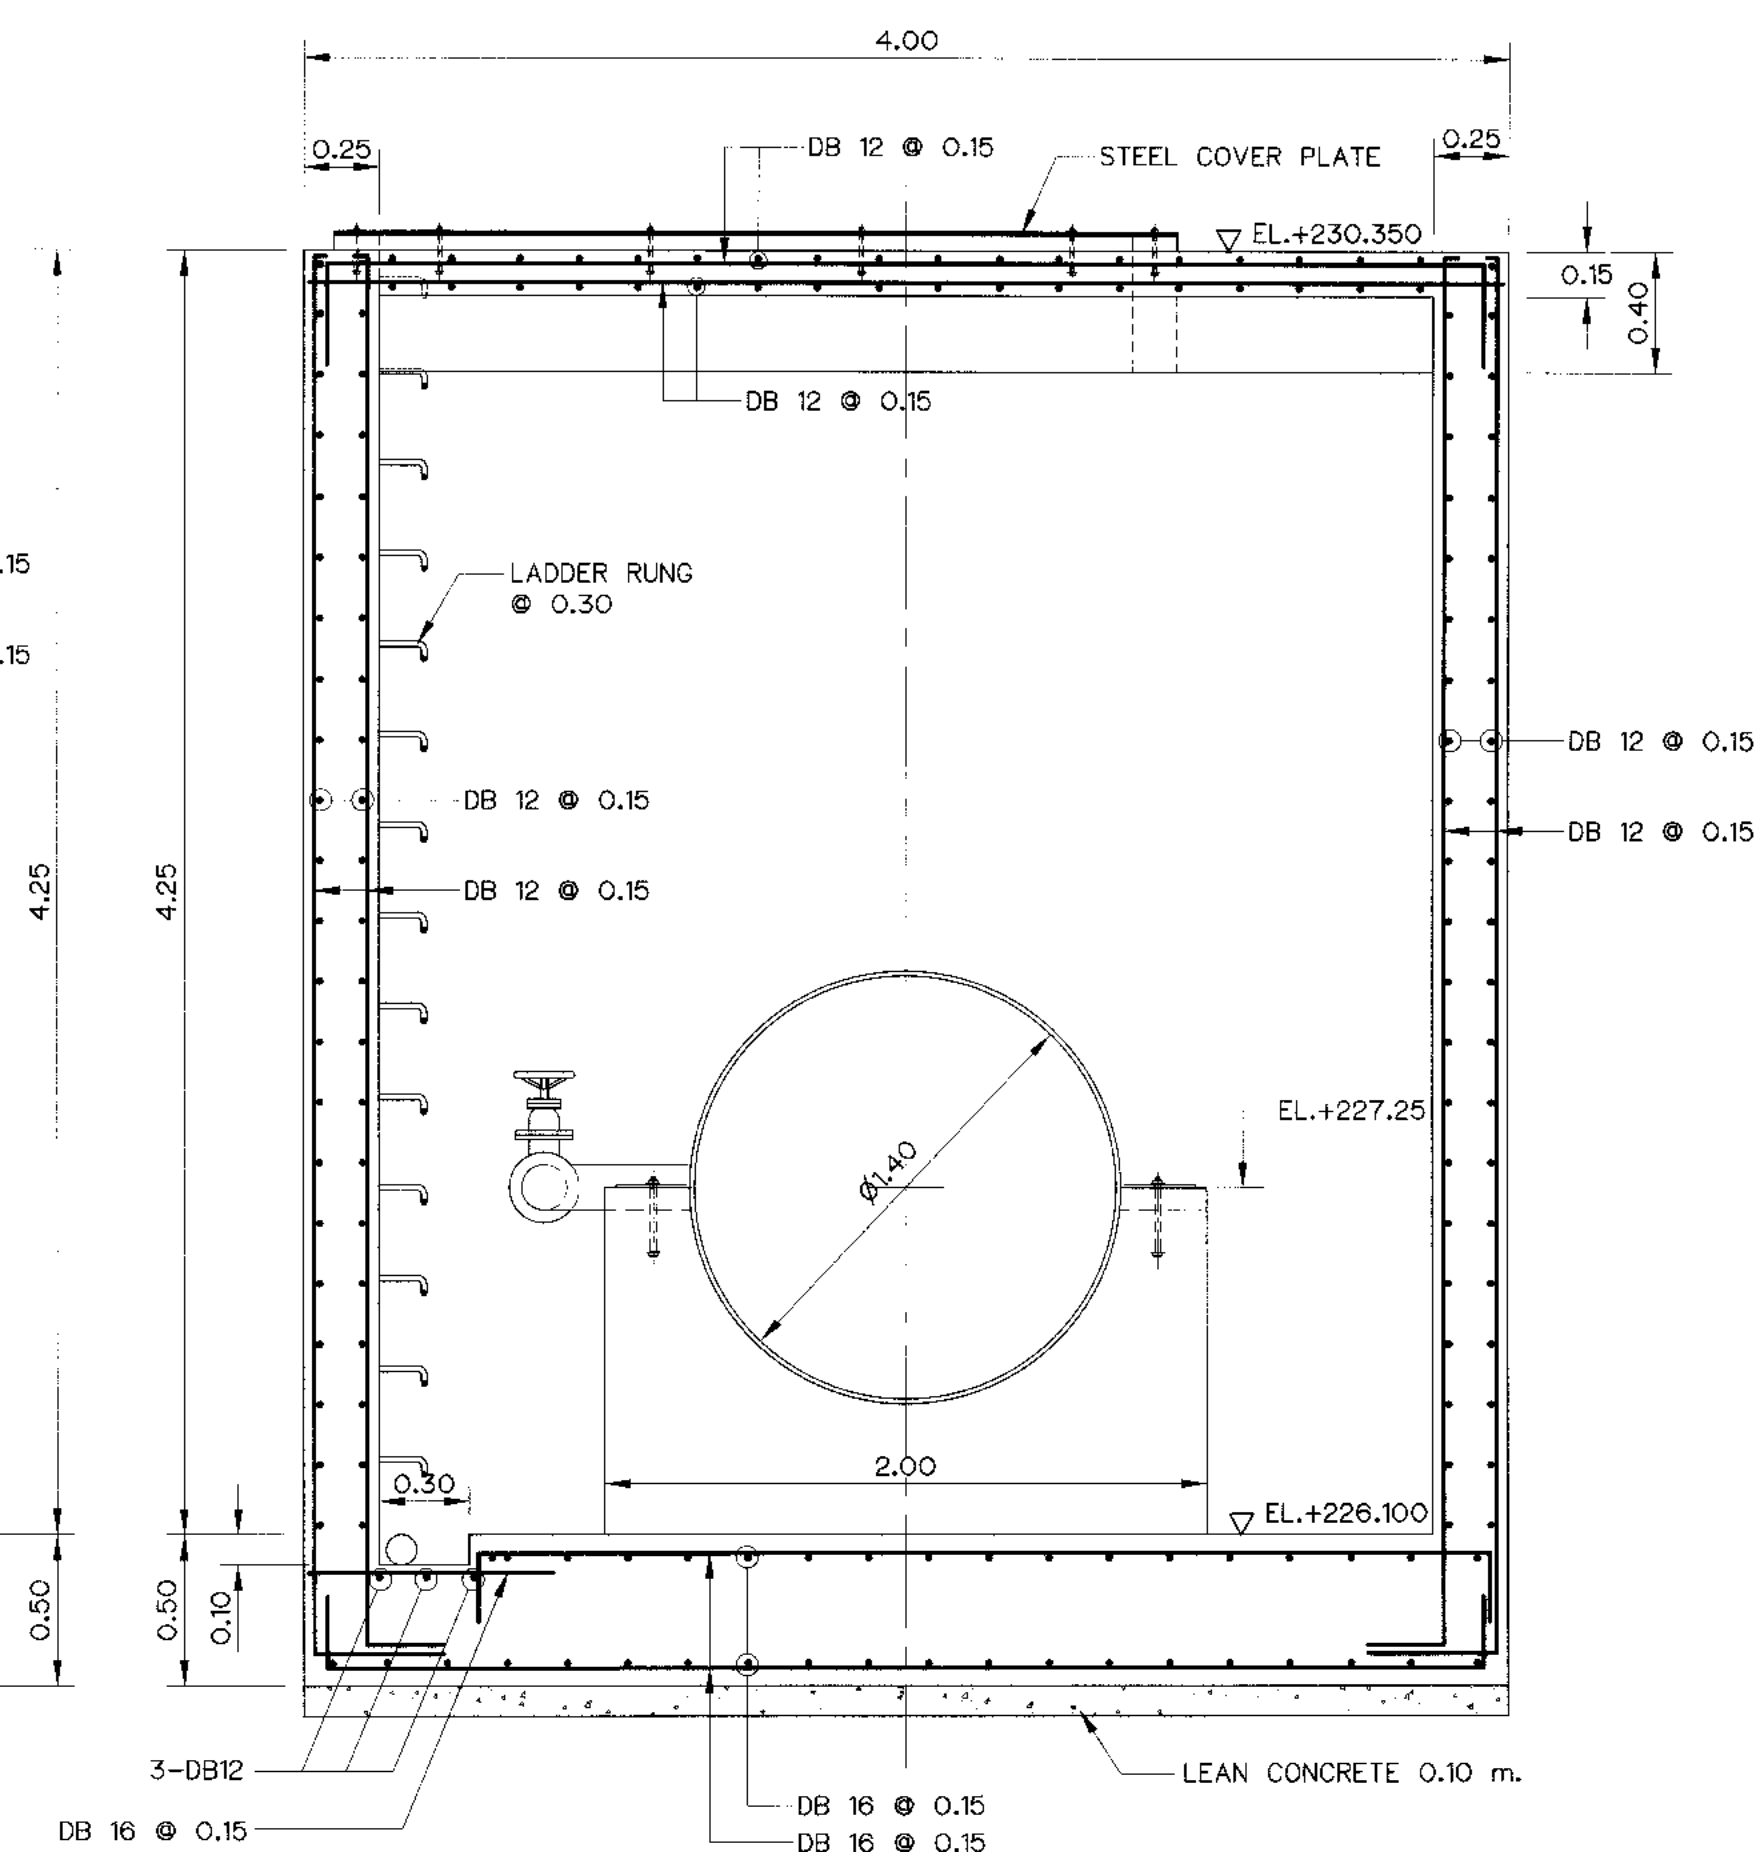

SECTION C-C
SCALE 1:25

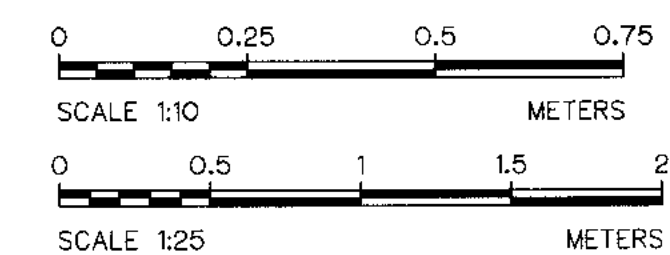


NOTE :


1. ALL DIMENSIONS AND ELEVATIONS ARE IN METERS, UNLESS OTHERWISE SHOWN

REFERENCE DRAWING :

1. EMERGENCY VALVE CHAMBER PLAN SECTIONS AND DETAILS KLP-ST-07

KINGDOM OF THAILAND Department of Alternative Energy Development and Efficiency MINISTRY OF ENERGY					KLONG LAM PLOK HYDROPOWER PROJECT				
CIVIL WORKS AND TRANSMISSION LINE					SURGE TANK				
EMERGENCY VALVE CHAMBER REINFORCEMENT DETAILS									
P&C MANAGEMENT CO.,LTD.					MINISTRY OF ENERGY				
DESIGNED	18/28074	08/03/2559	08/03/2559	08/03/2559	REVIEWED	08/03/2559	08/03/2559	08/03/2559	08/03/2559
DRAWN					RECOMMENDED				
CHECKED					APPROVED				
PROJECT MANAGER					DATE				
CONSULTANTS					DEDE				
KLP-ST-08					55 OF 110				

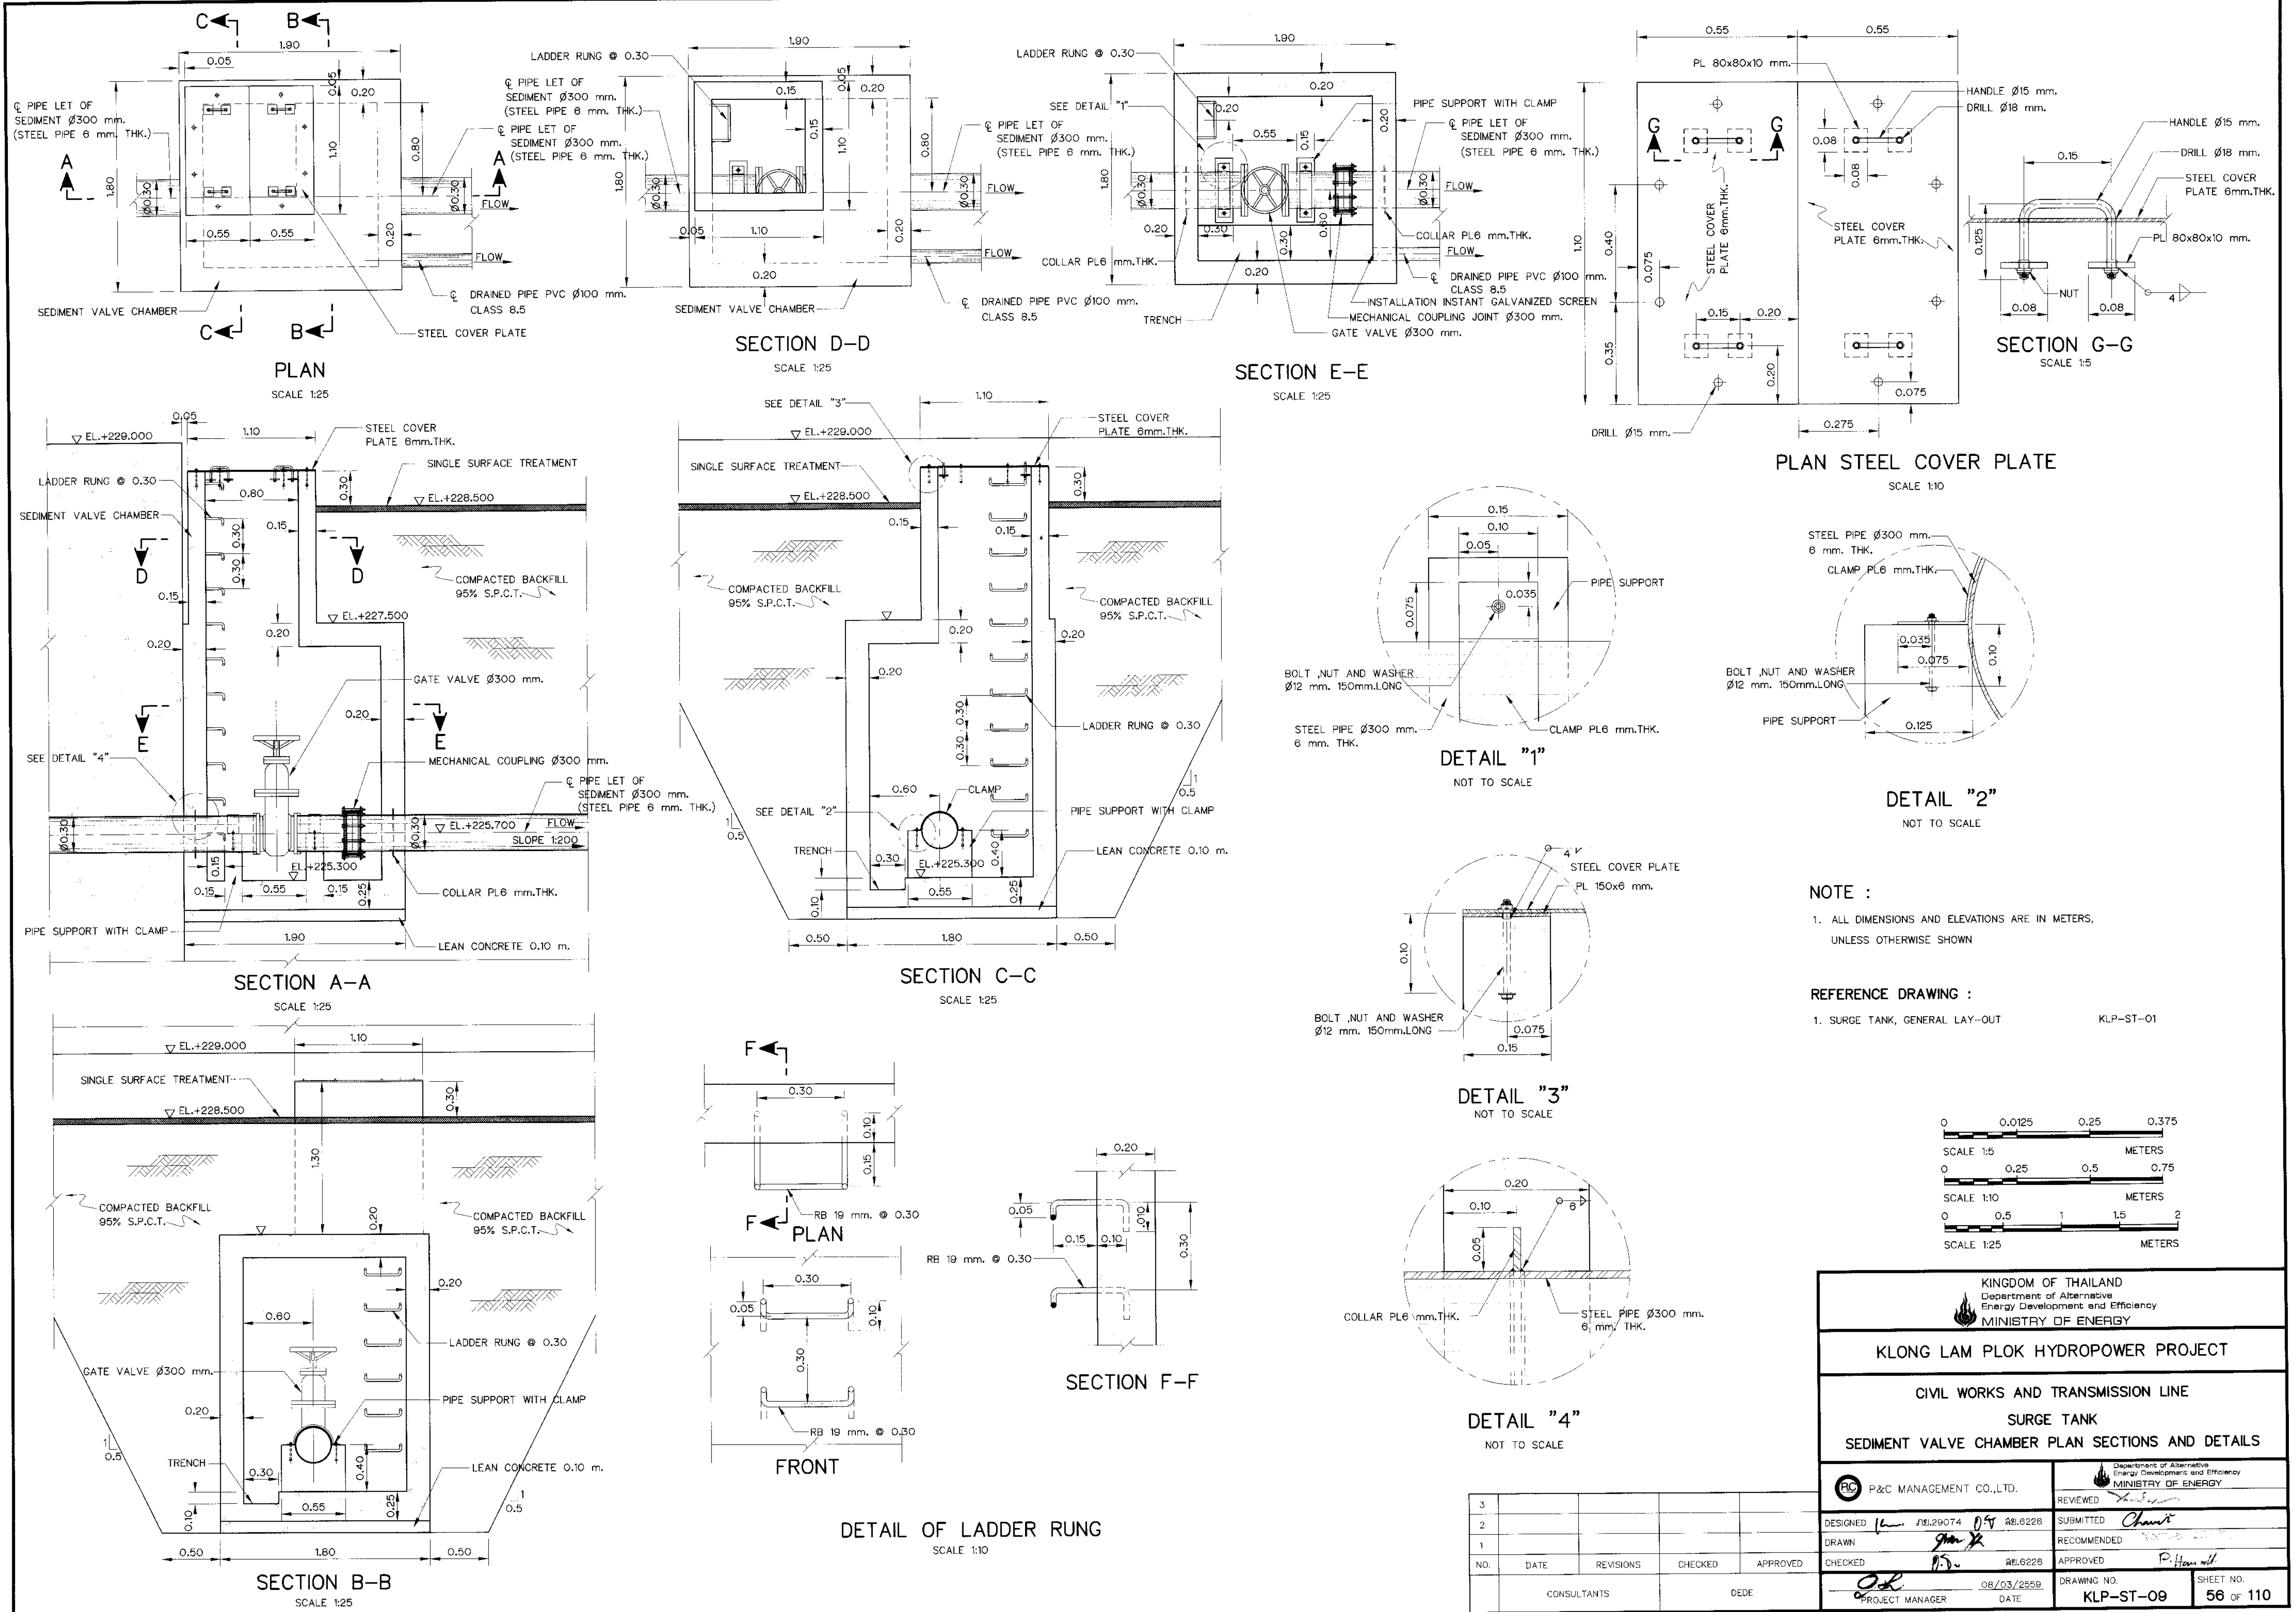

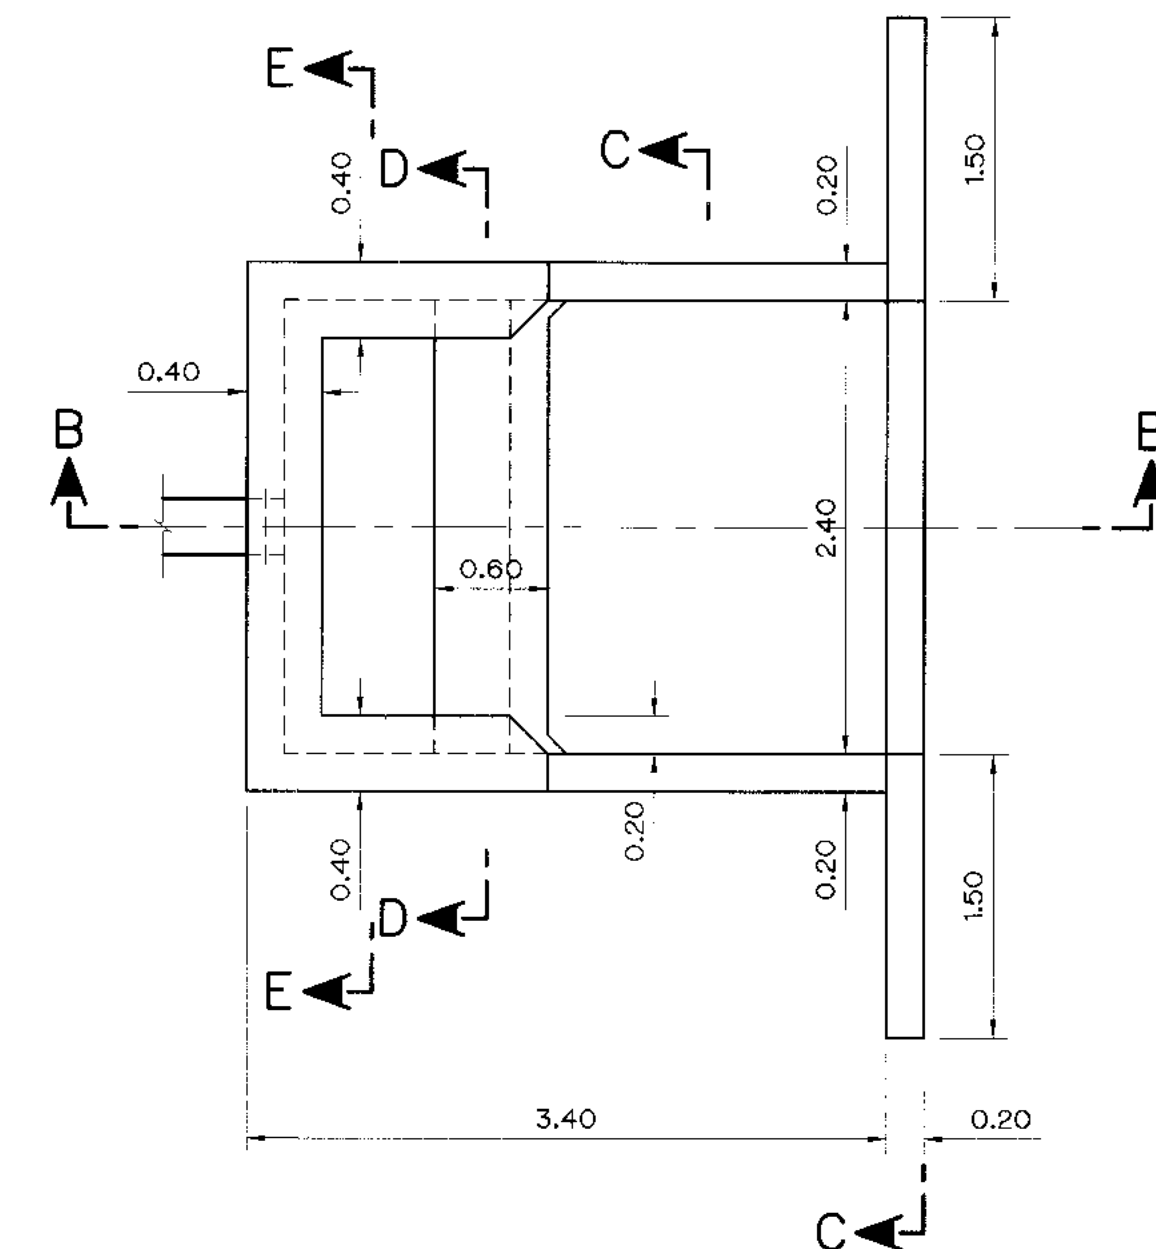

SECTION B-B
SCALE 1:40

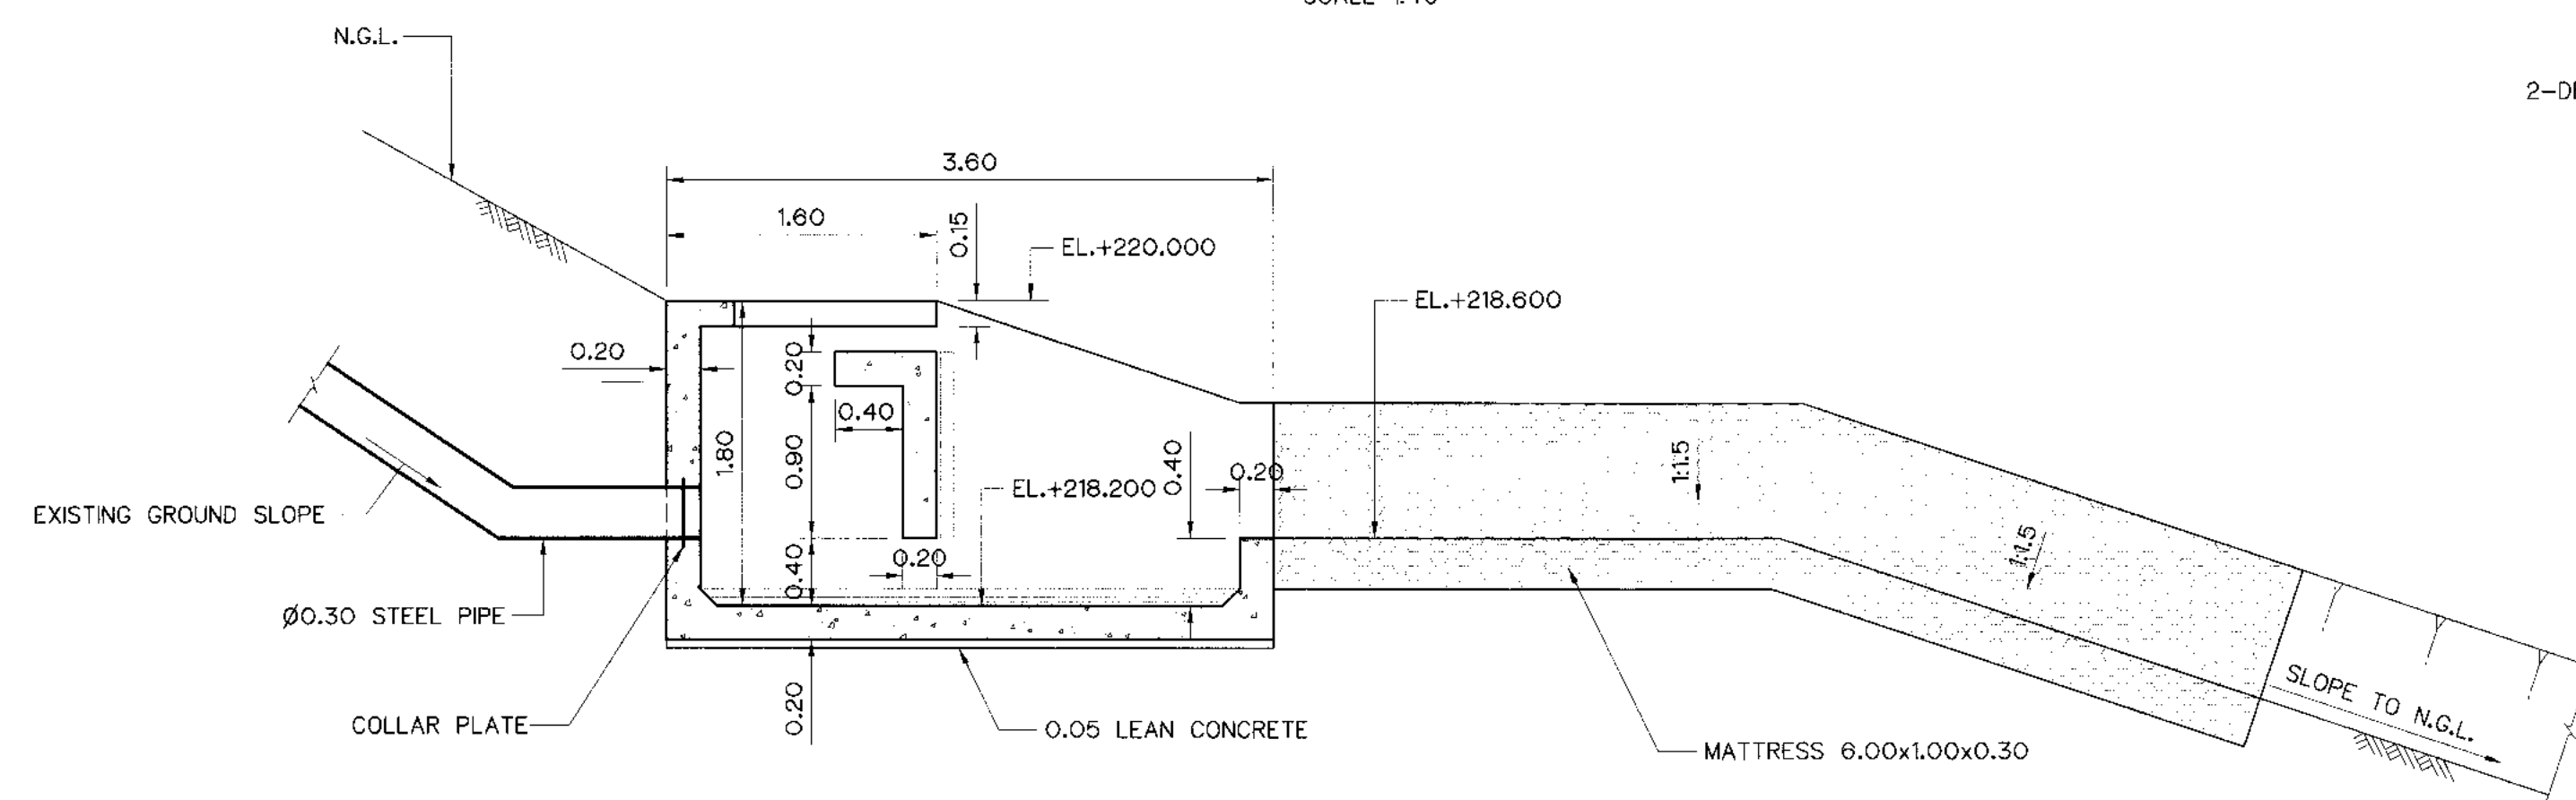


Figure 10 is a sectional view of a rectangular structure, likely a sediment outlet, showing dimensions and reinforcement details. The structure has a total width of 2.80 feet and a total height of 0.80 feet. The left side has a width of 1.30 feet. The central opening has a width of 0.20 feet. The bottom right corner has a 0.10 chamfer. Reinforcement bars are specified as DB12 @ 0.20 (edge bars), DB12 @ 0.20 (main bars), and DB12 @ 0.25 (main bars). A sediment outlet is shown at the top center.

S SEDIMENT OUTLET

2.80

0.40 0.15 0.40

1-DB12

2-DB12 (EDGE BARS)

DB12@0.25

DB12@0.25

DB12@0.20

4-DB12

DB12@0.25

DB12@0.20

0.40

0.20

DB12@0.25

DB12@0.25


DB12@0.20

DB12@0.25

Technical drawing of a rectangular sediment outlet structure. The drawing shows a rectangular frame with a central circular outlet. Dimensions include a total width of 2.60, a central outlet diameter of 0.10, and various reinforcement bar (DB12) specifications and counts. Labels include 'SEDIMENT OUTLET', '1-DB12', '2-DB12 (EDGE BARS)', 'DB12 Ø0.25', 'DB12 Ø0.20', '4-DB12', '0.10 CHAMFER', and 'DB12 Ø0.20'.


1. ALL DIMENSIONS AND ELEVATIONS (M.S.L.) ARE IN METERS, UNLESS OTHERWISE SHOWN.
2. SYMBOLS, ABBREVIATIONS AND GENERAL NOTES SEE DWG. NO. KLP-GN-03
3. CONCRETE DESIGN BASED ON THE COMPRESSIVE STRENGTH OF 210 KSC, STANDARD CYLINDER $\phi 0.15 \times 0.30$ m. TEST AT AGE 28 DAYS. UNLESS OTHERWISE INDICATED IN SPECIFIC DRAWINGS.
4. BEARING CAPACITY NOT LESS THAN 5 T/sq m

KLP-ST-01

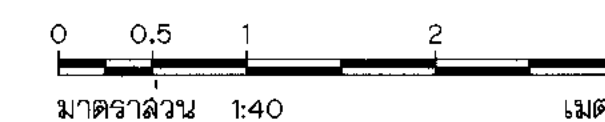

3				
2				
1				
NO.	DATE	REVISIONS	CHECKED	APPROVED
	CONSULTANTS		DEDE	

 KINGDOM OF THAILAND Department of Alternative Energy Development and Efficiency MINISTRY OF ENERGY	
KLONG LAM PLOK HYDROPOWER PROJECT	
CIVIL WORKS AND TRANSMISSION LINE SURGE TANK	
SEDIMENT OUTLET PLAN SECTION AND DETAILS	
 P&C MANAGEMENT CO., LTD.	 Department of Alternative Energy Development and Efficiency MINISTRY OF ENERGY
DESIGNED <i>W</i> 21.29074 02.21.6226	REVIEWED <i>[Signature]</i>
DRAWN <i>[Signature]</i>	SUBMITTED <i>Amel</i>
CHECKED <i>[Signature]</i> 21.21.6226	RECOMMENDED <i>[Signature]</i>
<i>[Signature]</i> 08/03/2559	APPROVED <i>P. Harned</i>
PROJECT MANAGER DATE	DRAWING NO. KLP-ST-11
	SHEET NO. 58 OF 110

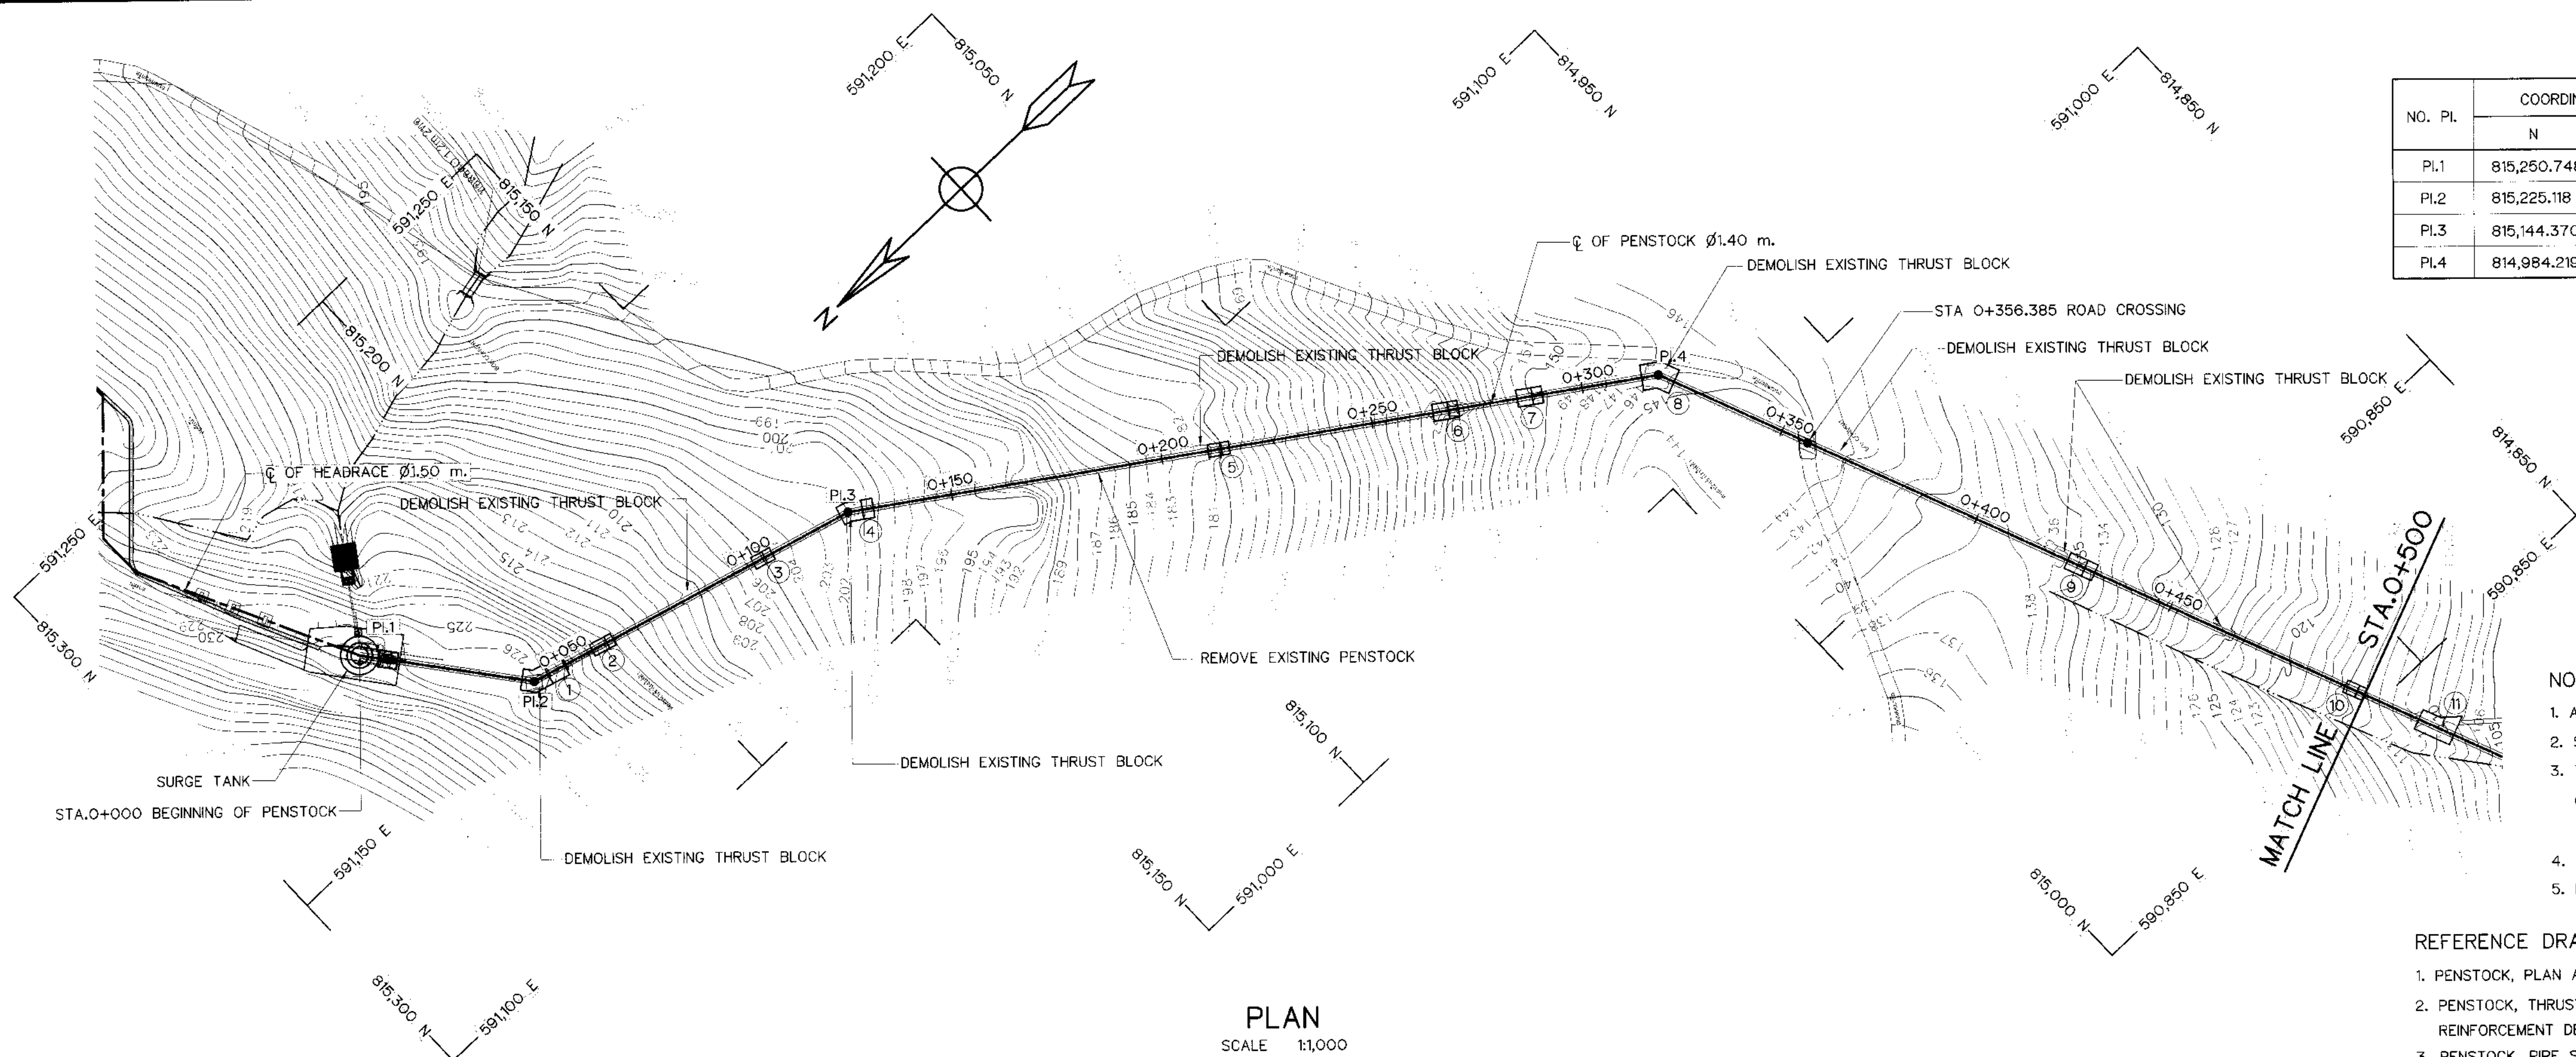

HORIZONTAL CURVE OF HEADRACE



NO. PI.	COORDINATE OF PI.		PI. TO PI. (m)	DEFLECTION ANGLE (Δ) (° - ' - ")	PI. STA. (km)	BEARING (N/S - ° - ' - " E/W)
	N	E				
PI.1	815,250.748	591,183.914	-	-	0+000.000	-
PI.2	815,225.118	591,151.169	41.583	36° - 44' - 08.88"	0+041.583	S 51° - 56' - 57.08" W
PI.3	815,144.370	591,129.210	83.681	18° - 39' - 52.83"	0+125.264	S 15° - 12' - 48.18" W
PI.4	814,984.219	591,021.682	192.901	33° - 44' - 59.21"	0+318.165	S 33° - 52' - 41.01" W

NOTES :

1. ALL DIMENSIONS AND ELEVATIONS (M.S.L.) ARE IN METERS, UNLESS OTHERWISE SHOWN.
2. SYMBOLS, ABBREVIATIONS AND GENERAL NOTES SEE DWG. NO. KLP-GN-03
3. THE ALIGNMENT OF THE PENSTOCK AND RELATED STRUCTURES SHALL BE CHECK AND CORRECTED BY THE CONTRACTOR TO SUIT THE FIELD CONDITIONS AND SHALL BE SUBMITTED TO DEDE'S FIELD ENGINEER FOR APPROVAL
4. REMOVE EXISTING HEADRACE
5. DEMOLISHED EXISTING THRUST BLOCKS

REFERENCE DRAWINGS :


1. PENSTOCK, PLAN AND PROFILE, STA. 0+500 TO STA. 0+693.571 KLP-PS-02
2. PENSTOCK, THRUST BLOCK PLAN, SECTIONS REINFORCEMENT DETAILS 1/5 TO 5/5 KLP-PS-03 TO 07
3. PENSTOCK, PIPE SUPPORT, PLAN, SECTIONS AND DETAILS KLP-PS-08
4. PENSTOCK, ROAD CROSSING PLAN, SECTIONS REINFORCEMENT KLP-PS-14
5. HEADRACE, PIER SUPPORT FOR STA. 0+000 TO STA. 0+044.583 OF PENSTOCK KLP-HR-08

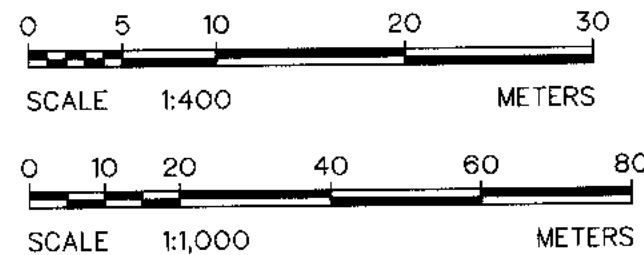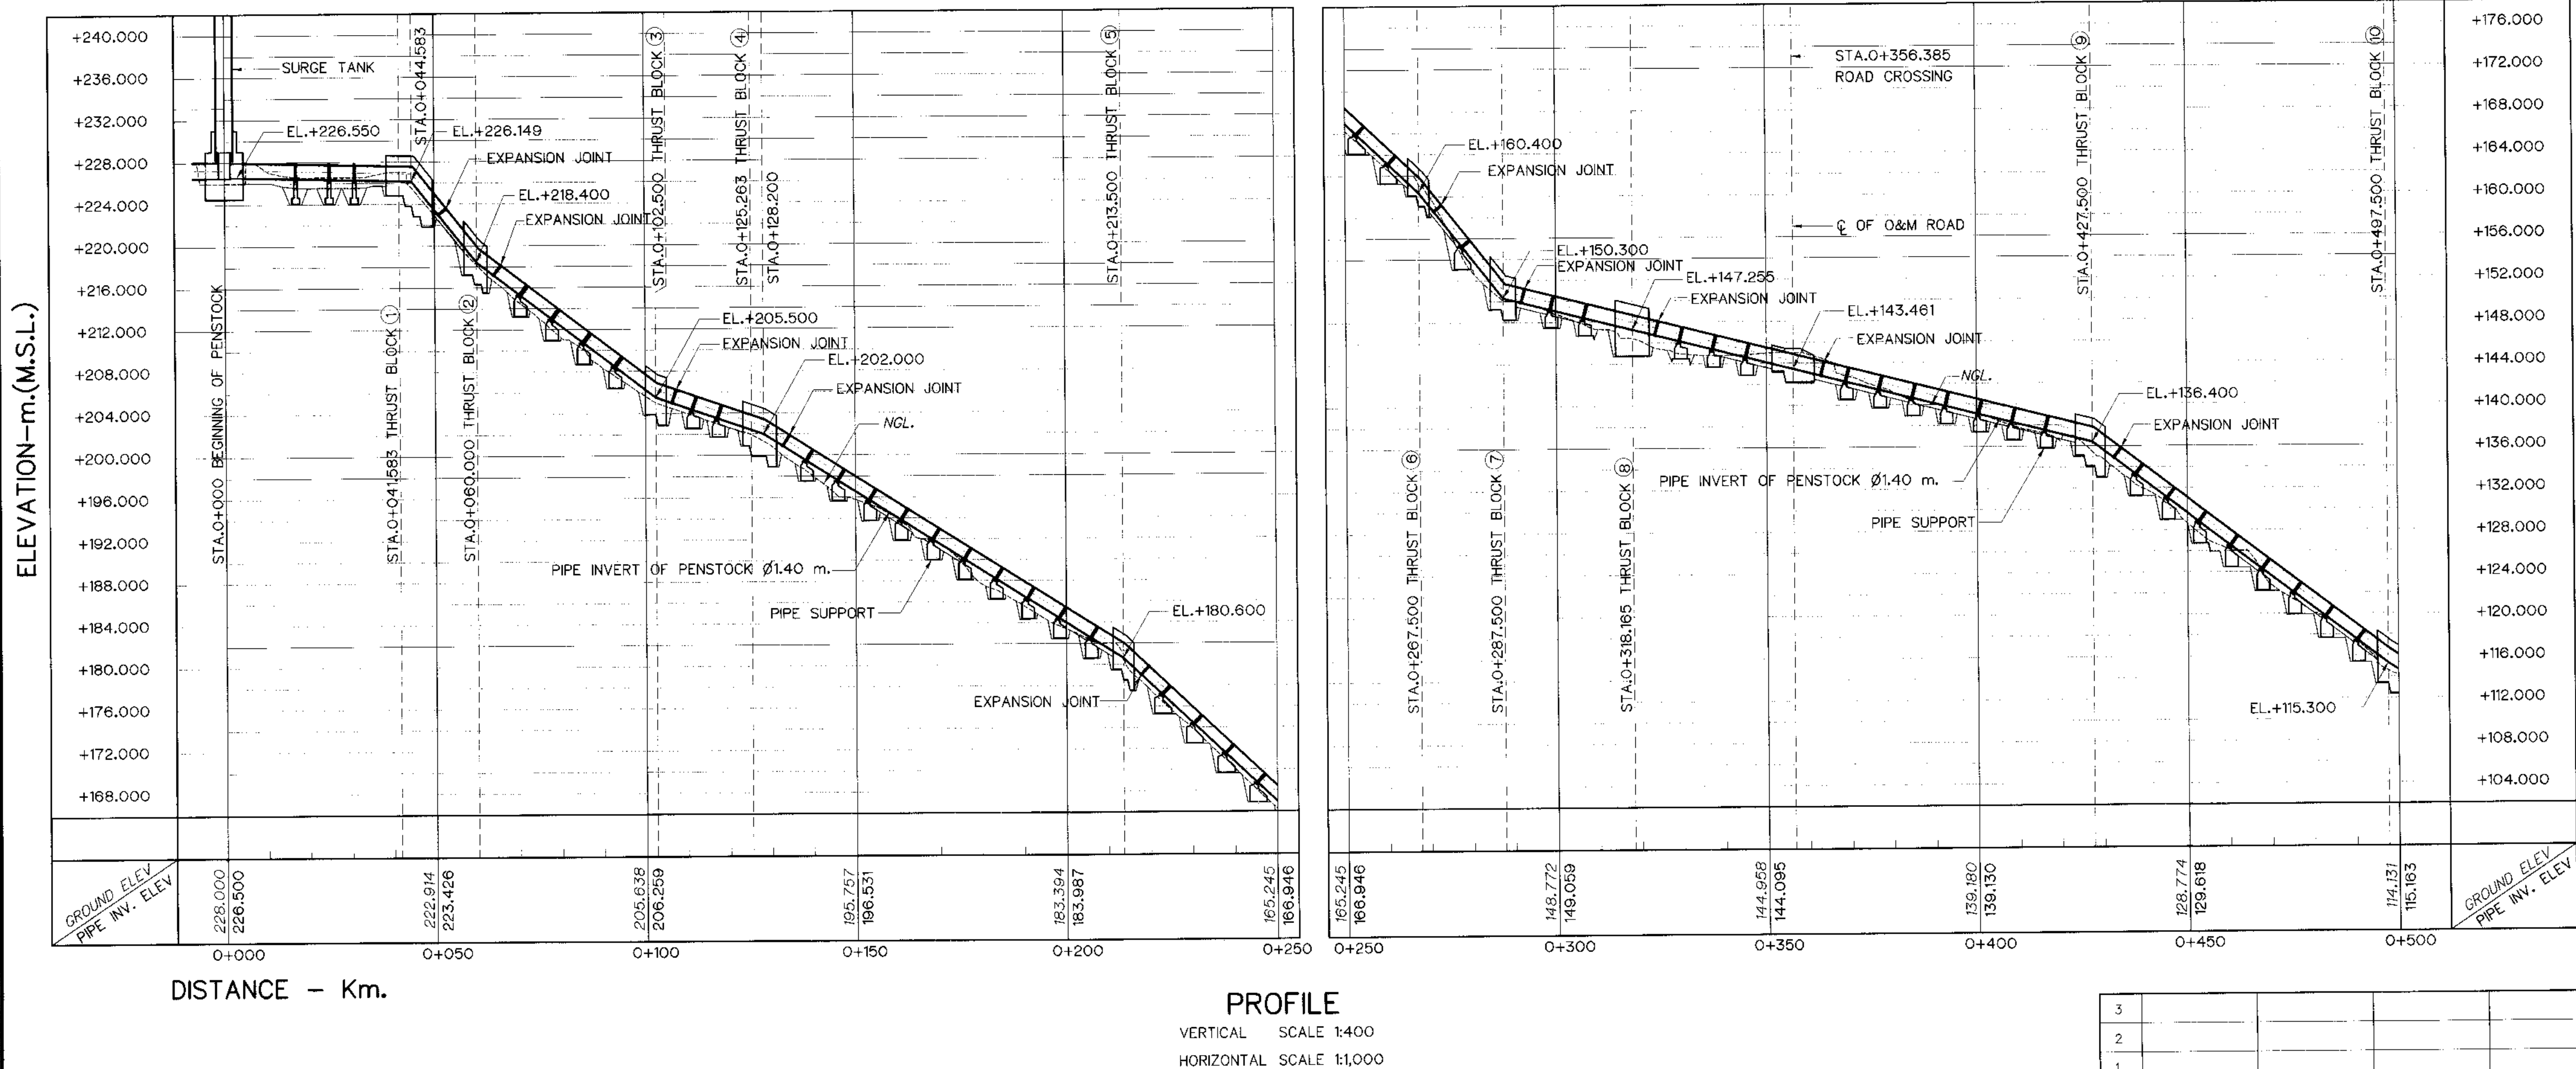

ELEVATION-m.(M.S.L.)

ELEVATION-m.(M.S.L.)

KINGDOM OF THAILAND Department of Alternative Energy Development and Efficiency MINISTRY OF ENERGY	
KLONG LAM PLOK HYDROPOWER PROJECT	
CIVIL WORKS AND TRANSMISSION LINE	
PENSTOCK	
PLAN AND PROFILE, STA. 0+000 TO STA. 0+500	
DESIGNED <i>[Signature]</i> 08/29/07 0.7 281.6226 DRAWN <i>[Signature]</i> CHECKED <i>[Signature]</i> 08/29/07 281.6226 PROJECT MANAGER <i>[Signature]</i> 08/29/07 281.6226	REVIEWED <i>[Signature]</i> SUBMITTED <i>[Signature]</i> RECOMMENDED <i>[Signature]</i> APPROVED <i>[Signature]</i> DRAWING NO. KLP-PS-01 SHEET NO. 59 OF 110

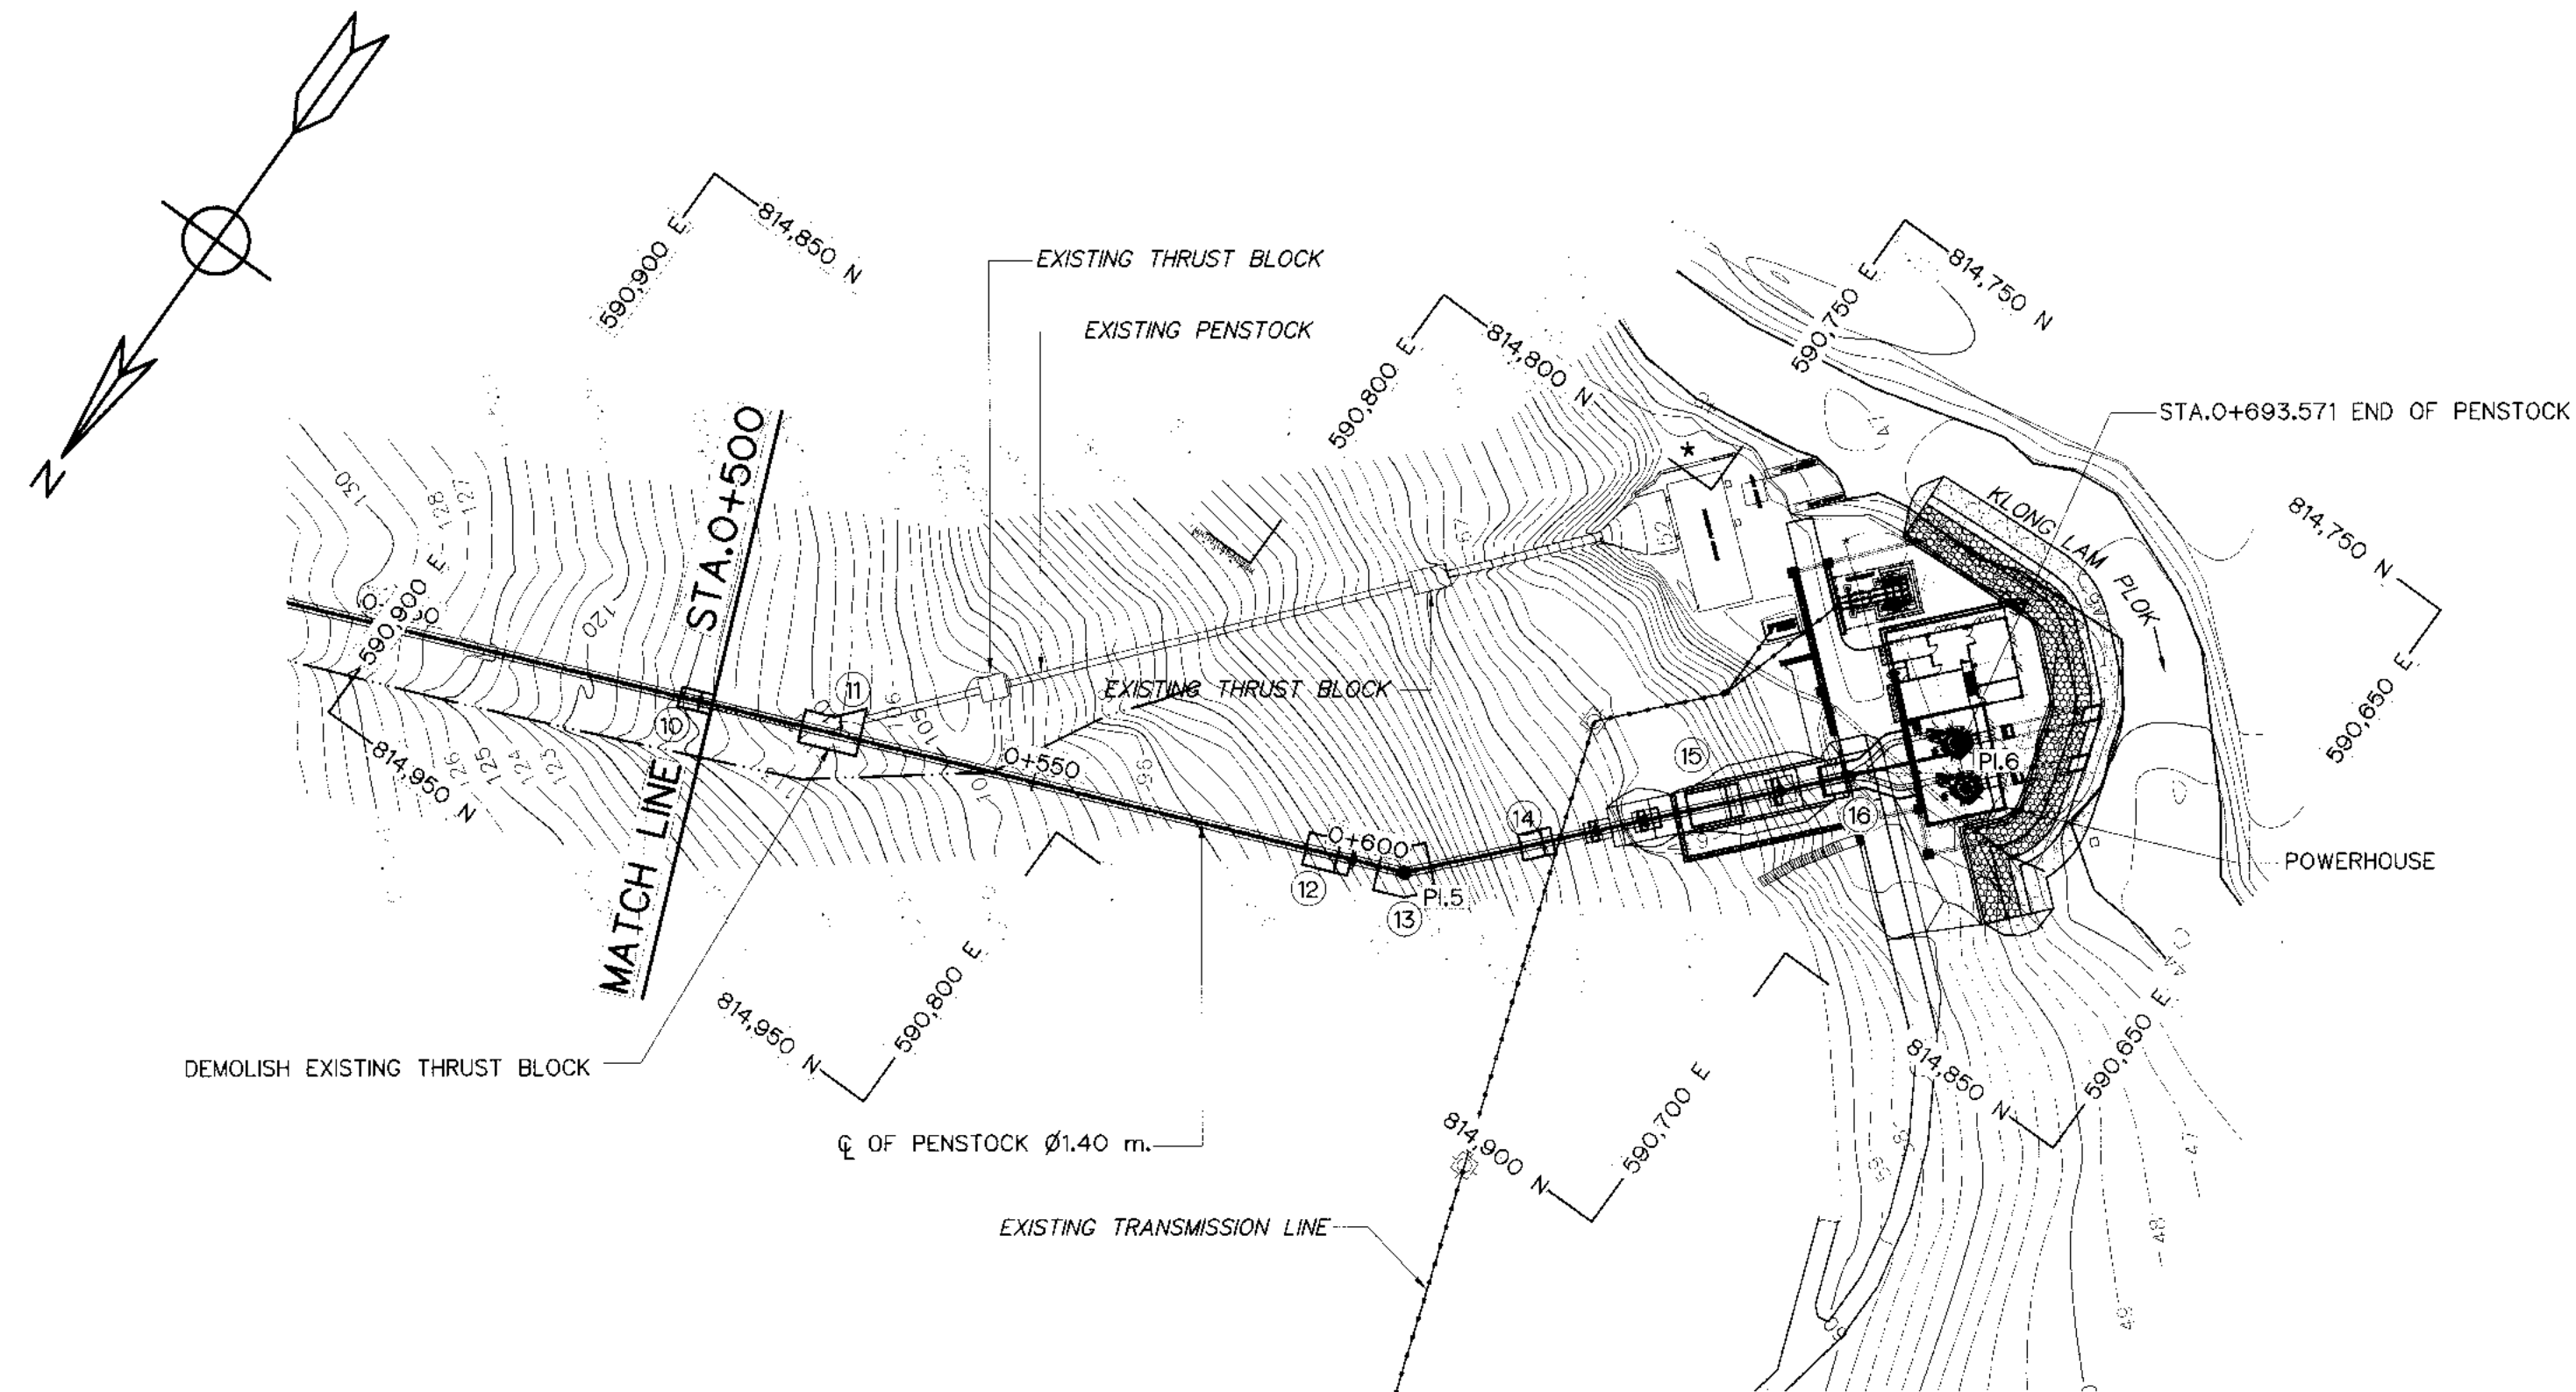


PLAN
SCALE 1:1,000

NO. PL.	COORDINATE OF PL.		PL. TO PL. (m)	DEFLECTION ANGLE (Δ) (' - ' - ")	PL. STA. (km)	BEARING (N/S ' - ' - " E/W)
	N	E				
PL.5	814,873.965	590,753.808	289.678	25' - 42' - 42.07"	0+607.842	S 67° - 37' - 40.22" W
PL.6	814,810.169	590,696.571	85.729		0+693.571	

NOTES :

- ALL DIMENSIONS AND ELEVATIONS (M.S.L.) ARE IN METERS, UNLESS OTHERWISE SHOWN.
- SYMBOLS, ABBREVIATIONS AND GENERAL NOTES SEE DWG. NO. KLP-GN-03
- THE ALIGNMENT OF THE PENSTOCK AND RELATED STRUCTURES SHALL BE CHECK AND CORRECTED BY THE CONTRACTOR TO SUIT THE FIELD CONDITIONS AND SHALL BE SUBMITTED TO DEDE'S FIELD ENGINEER FOR APPROVAL

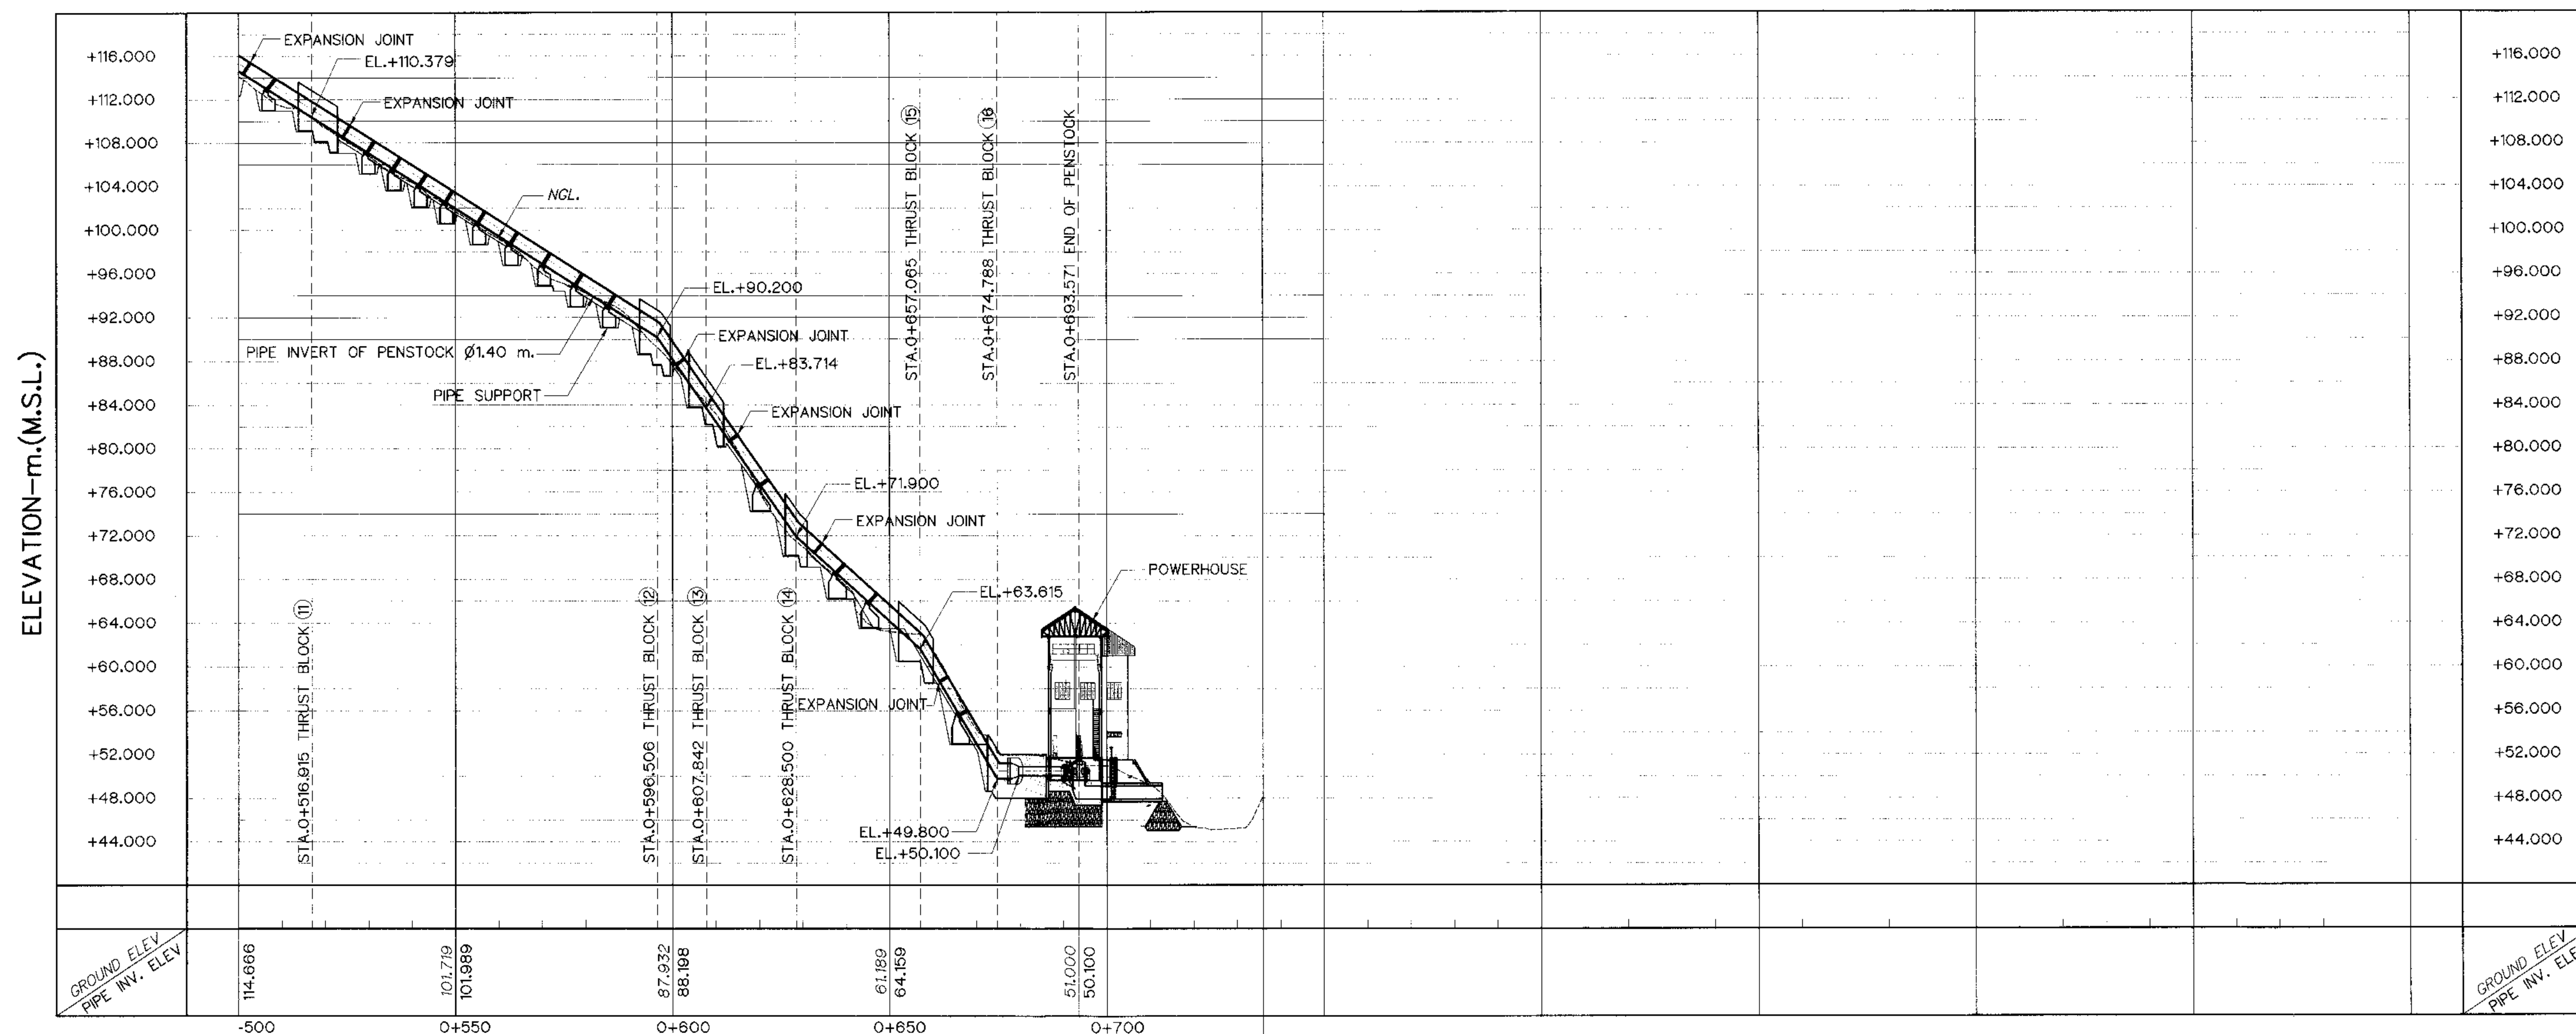


DISTANCE - Km.

PROFILE
VERTICAL SCALE 1:400
HORIZONTAL SCALE 1:1,000

REFERENCE DRAWINGS :


- PENSTOCK, PLAN AND PROFILE, STA. 0+000 TO STA. 0+000 KLP-PS-01
- PENSTOCK, THRUST BLOCK PLAN, SECTIONS REINFORCEMENT DETAILS 1/5 TO 5/5 KLP-PS-03 TO 07
- PENSTOCK, PIPE SUPPORT, PLAN, SECTIONS AND DETAILS KLP-PS-08

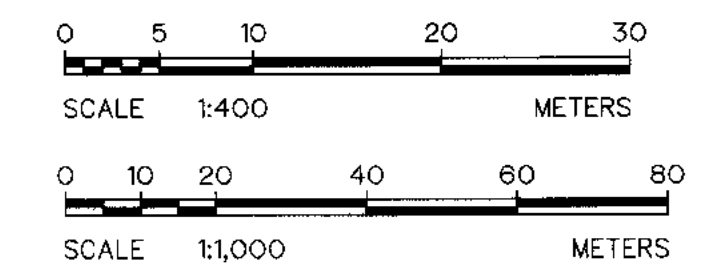


ELEVATION-m.(M.S.L.)

KINGDOM OF THAILAND Department of Alternative Energy Development and Efficiency MINISTRY OF ENERGY	
KLONG LAM PLOK HYDROPOWER PROJECT	
CIVIL WORKS AND TRANSMISSION LINE PENSTOCK PLAN AND PROFILE, STA. 0+500 TO STA. 0+693.571	
DESIGNED <i>[Signature]</i> 281.29074 DRAWN <i>[Signature]</i> CHECKED <i>[Signature]</i> 281.6226 PROJECT MANAGER	REVIEWED <i>[Signature]</i> SUBMITTED <i>[Signature]</i> RECOMMENDED <i>[Signature]</i> APPROVED <i>[Signature]</i> 281.6226 DATE 08/03/2569
CONSULTANTS	DEDE
DRAWING NO. KLP-PS-02	SHEET NO. 60 OF 110


3				
2				
1				
NO.	DATE	REVISIONS	CHECKED	APPROVED

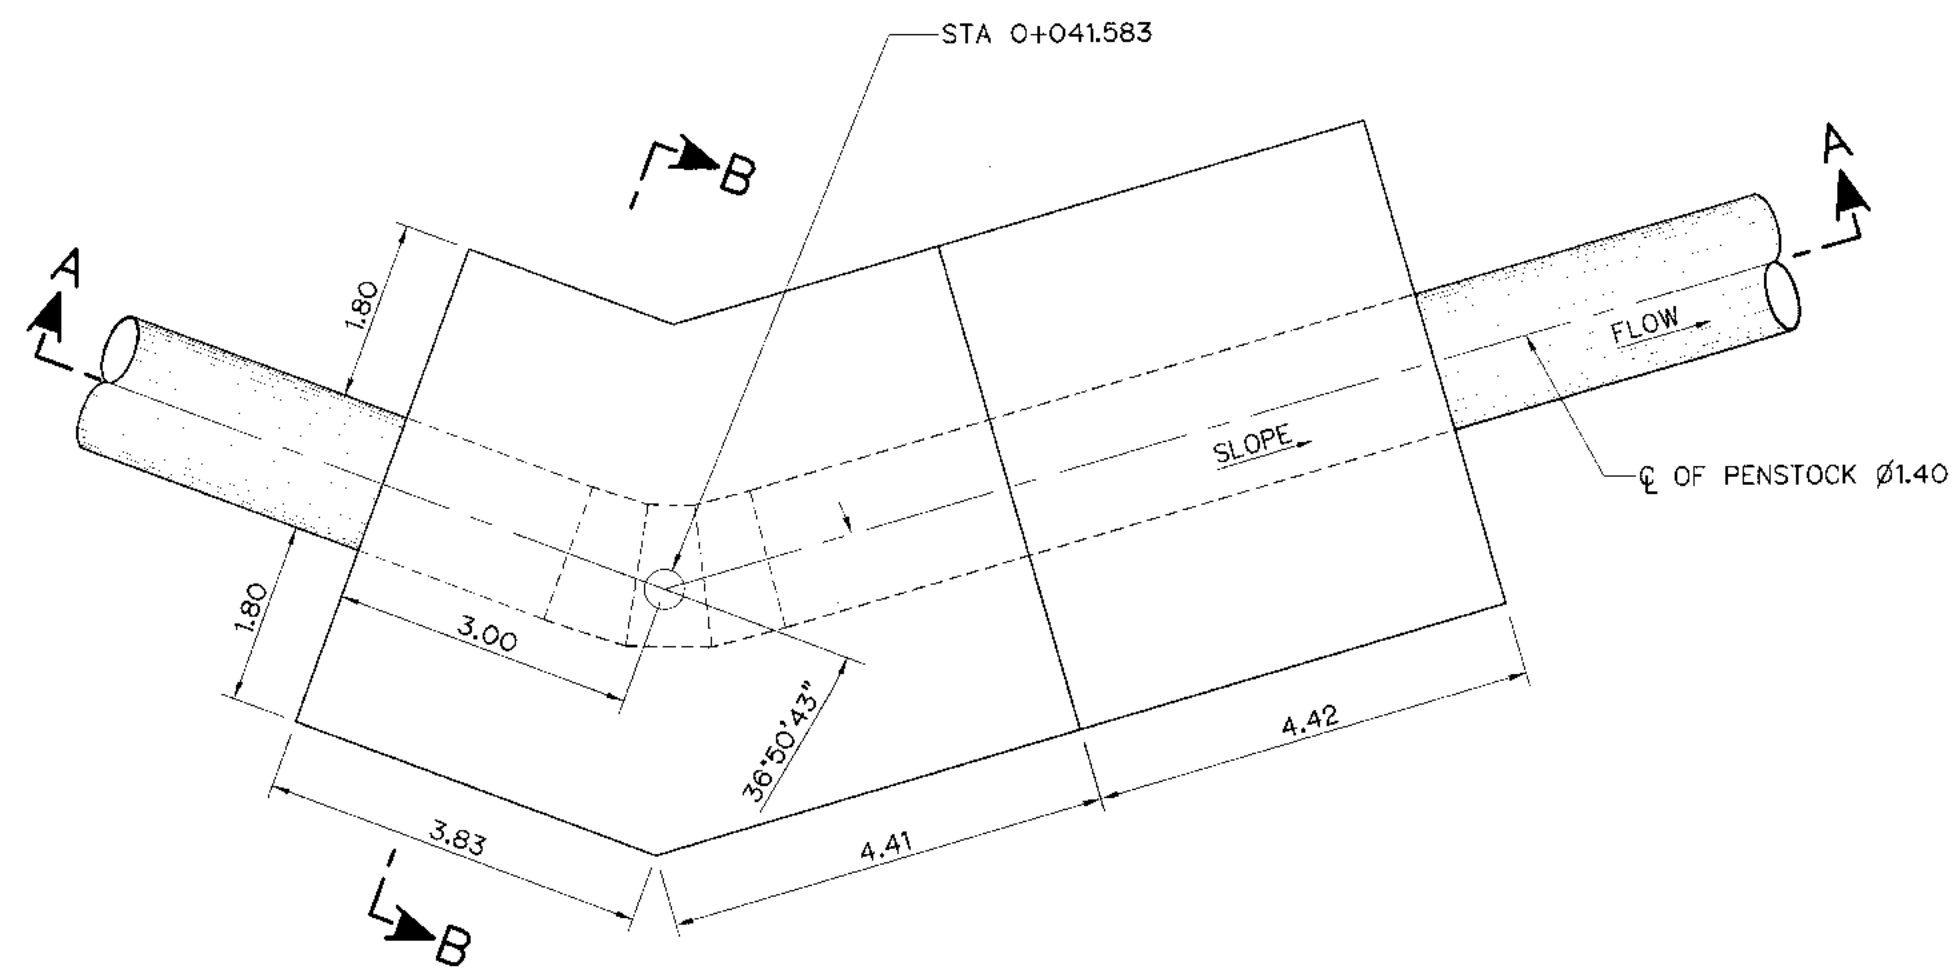


PLAN (THRUST BLOCK ①)
SCALE 1:75

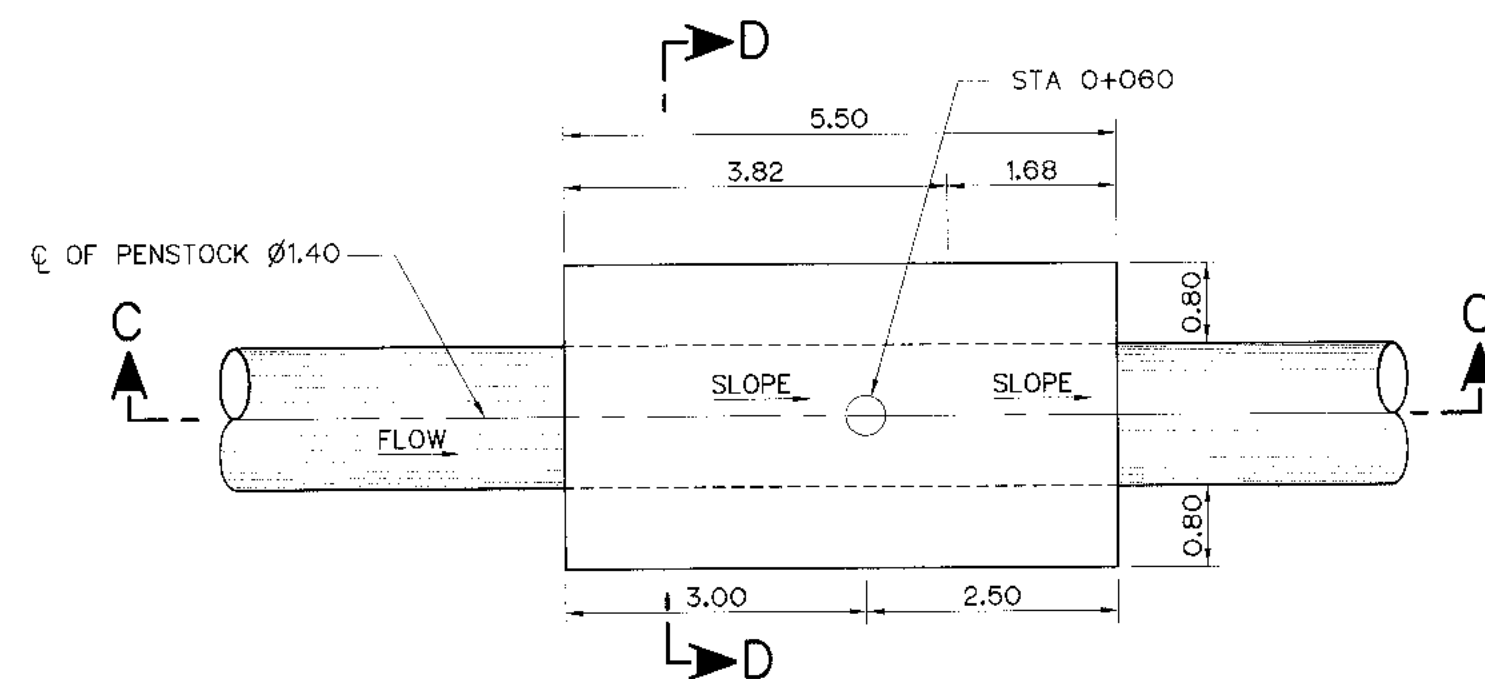


PLAN (THRUST BLOCK ②)
SCALE 1:75

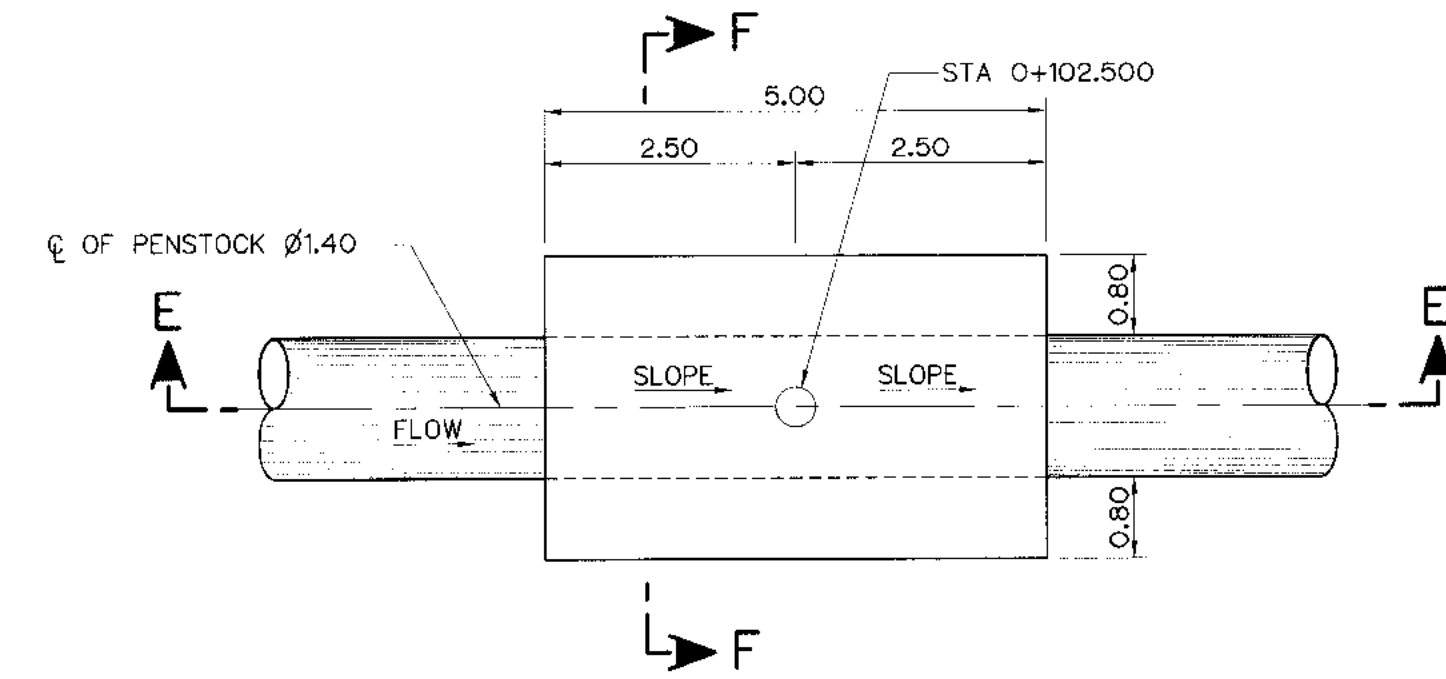


PLAN (THRUST BLOCK ③)
SCALE 1:75

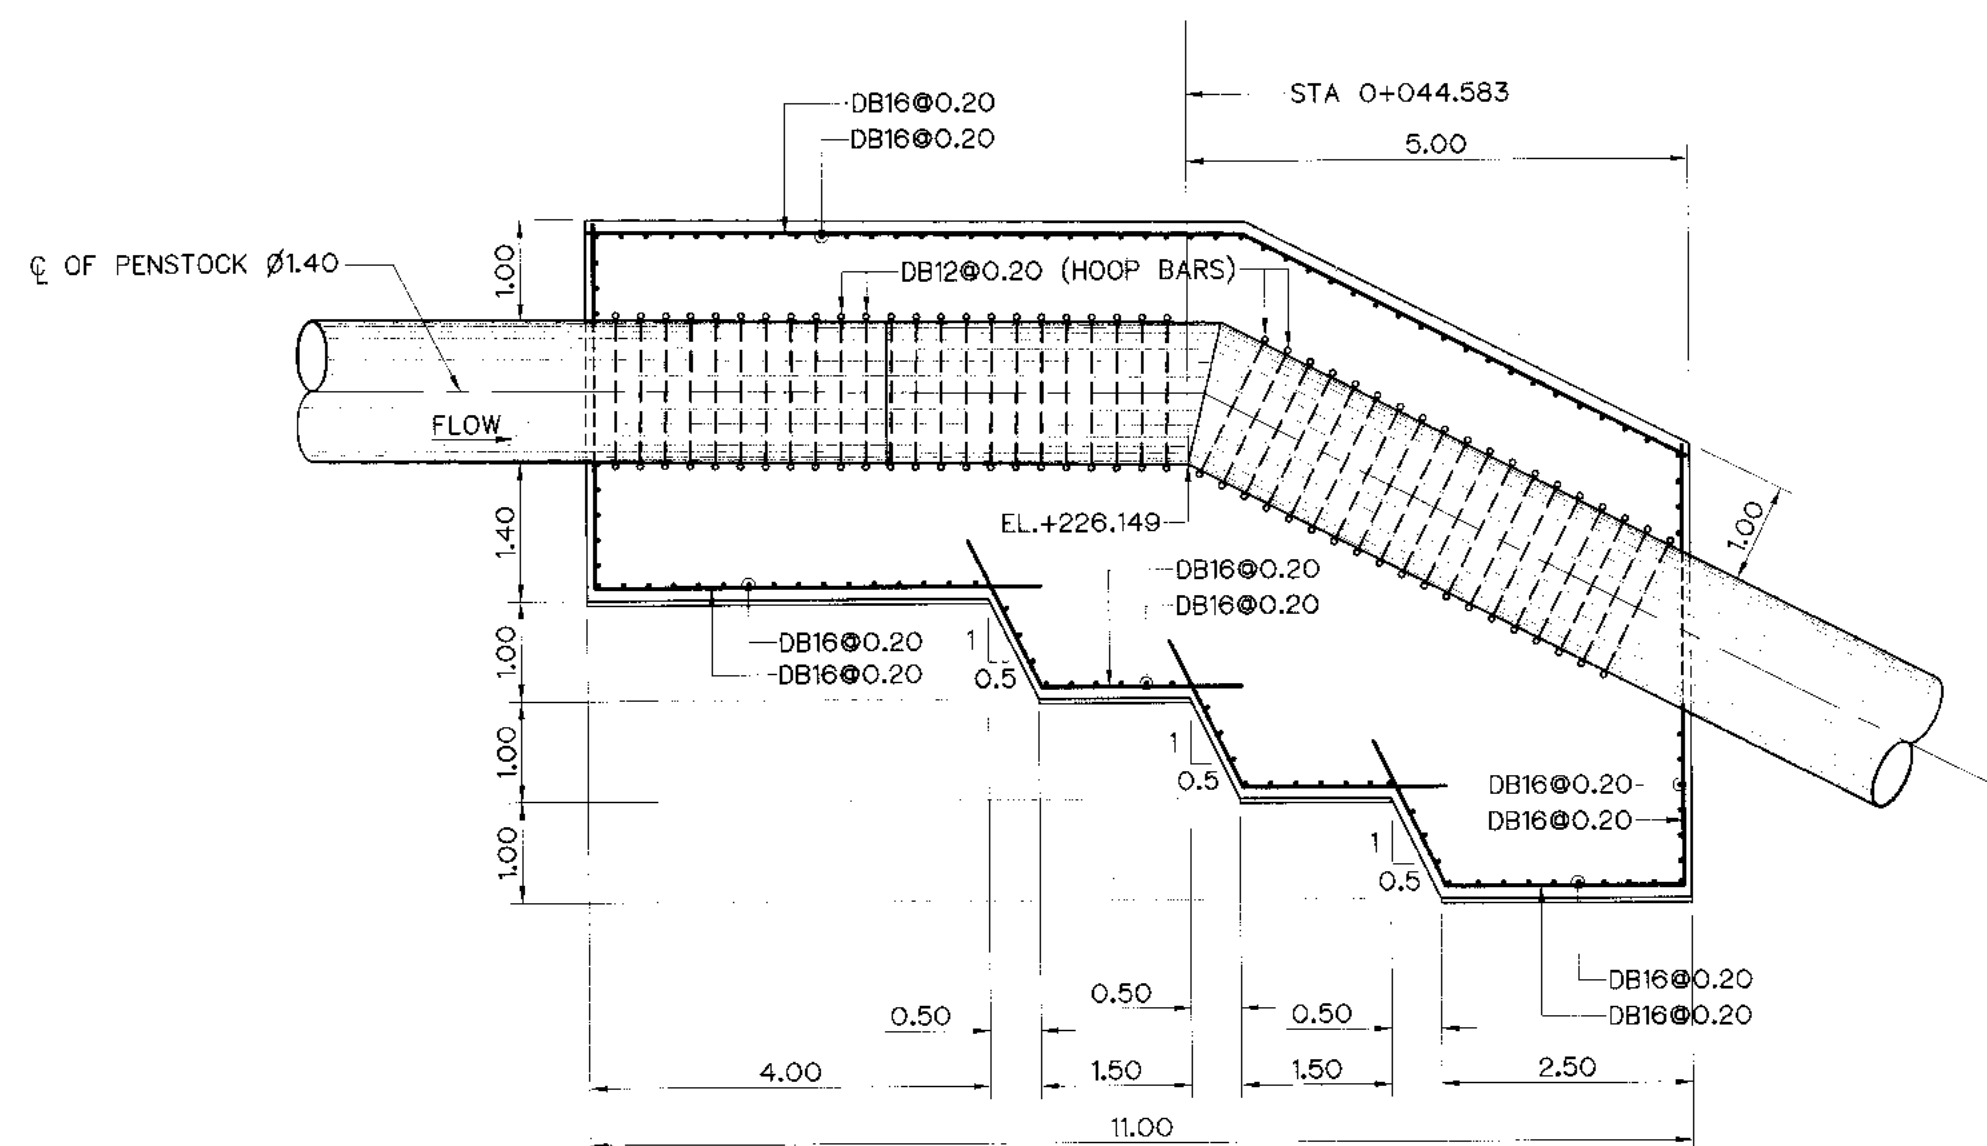


SECTION A-A
SCALE 1:75

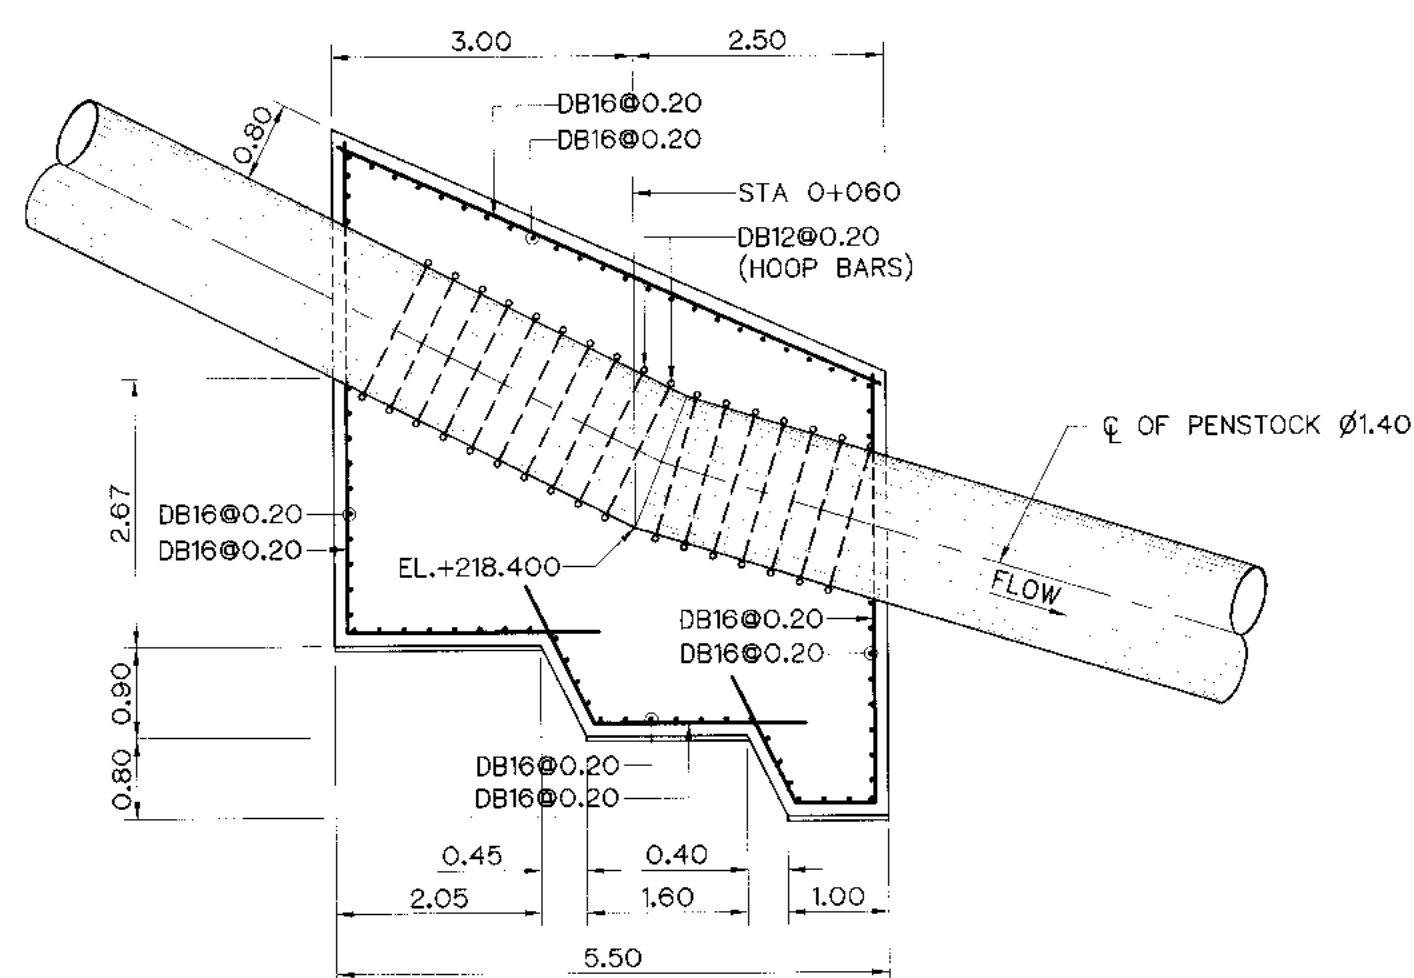


SECTION C-C
SCALE 1:75

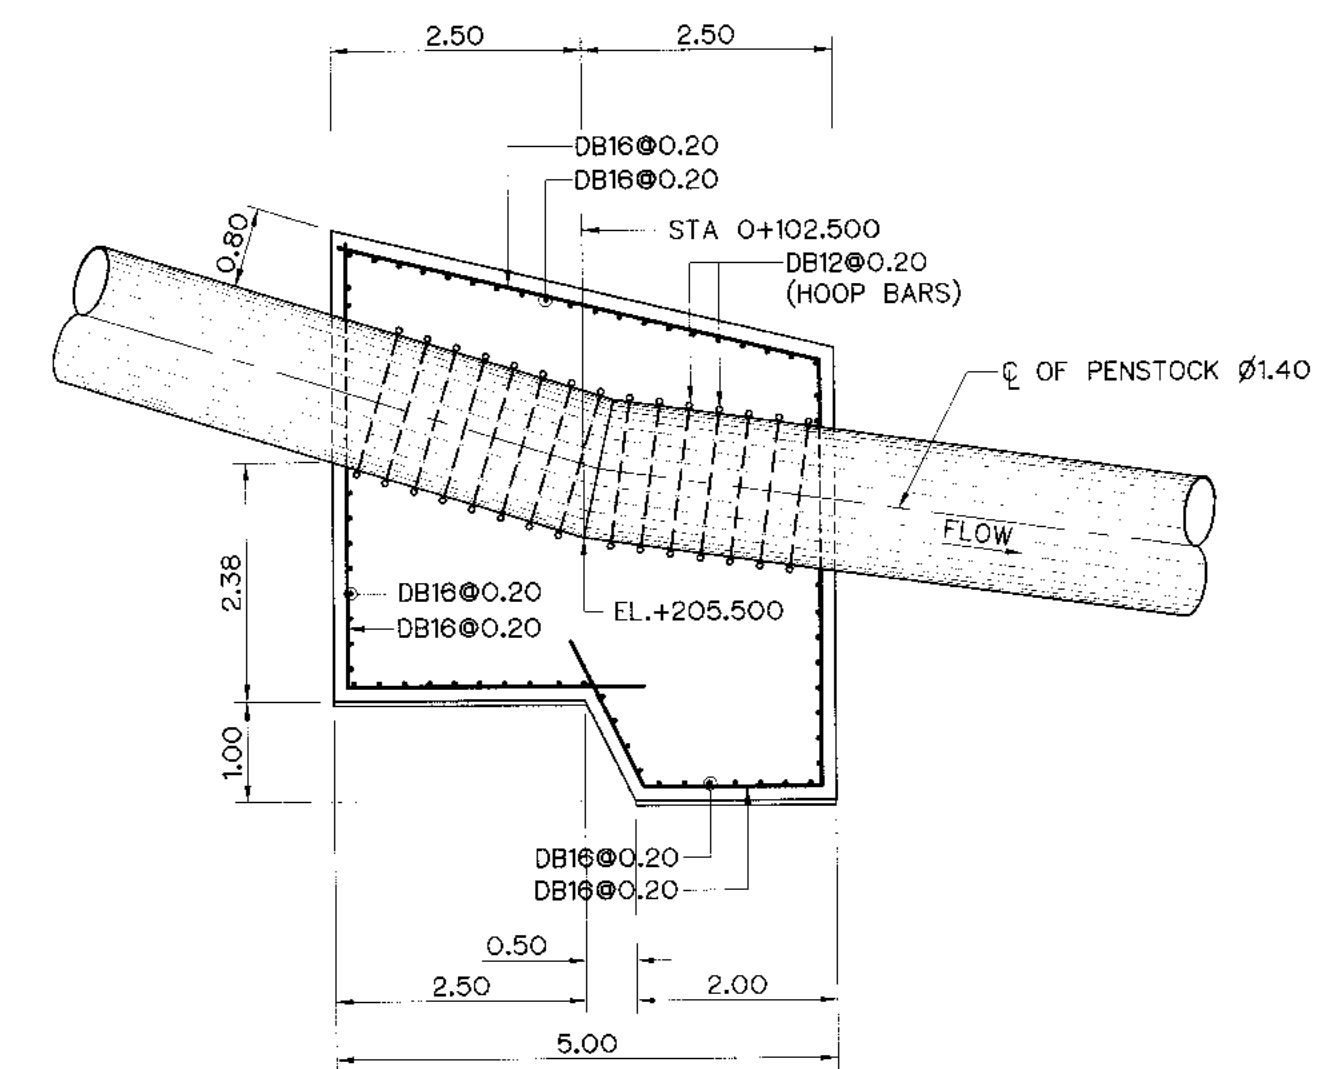


SECTION E-E
SCALE 1:75

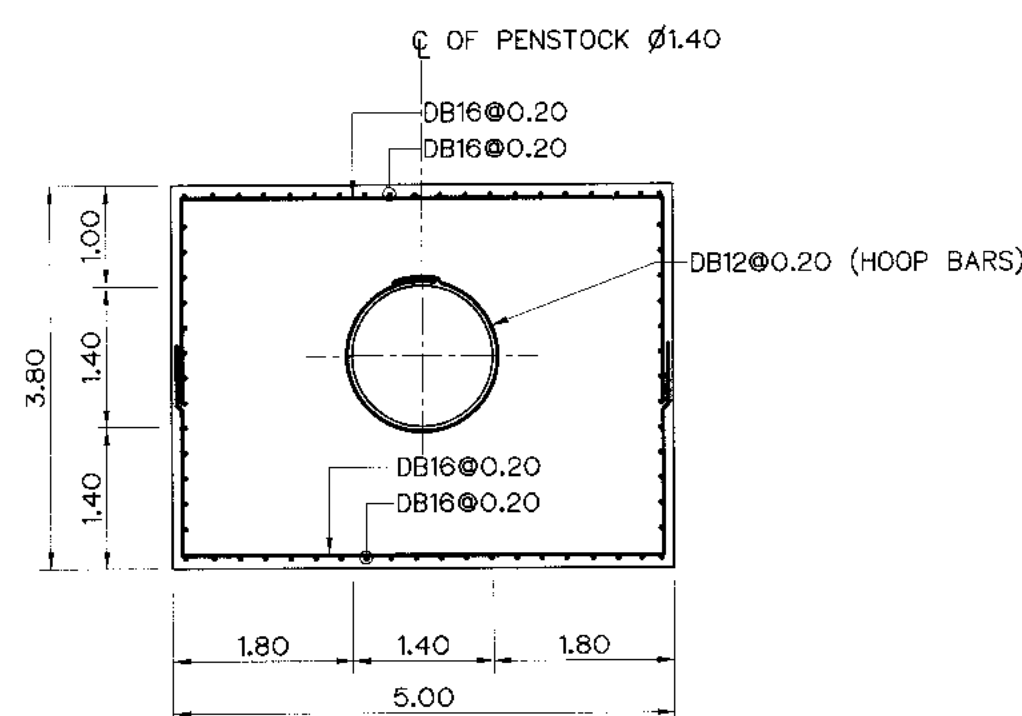


SECTION B-B
SCALE 1:75

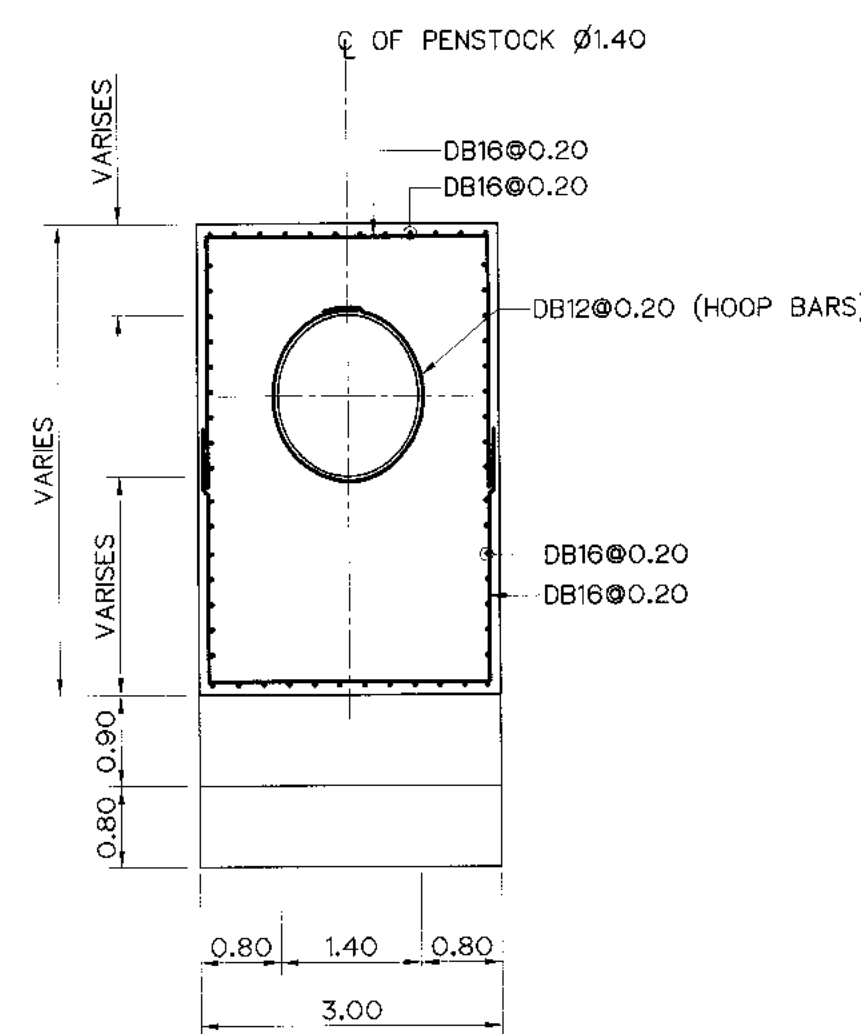

SECTION D-D
SCALE 1:75

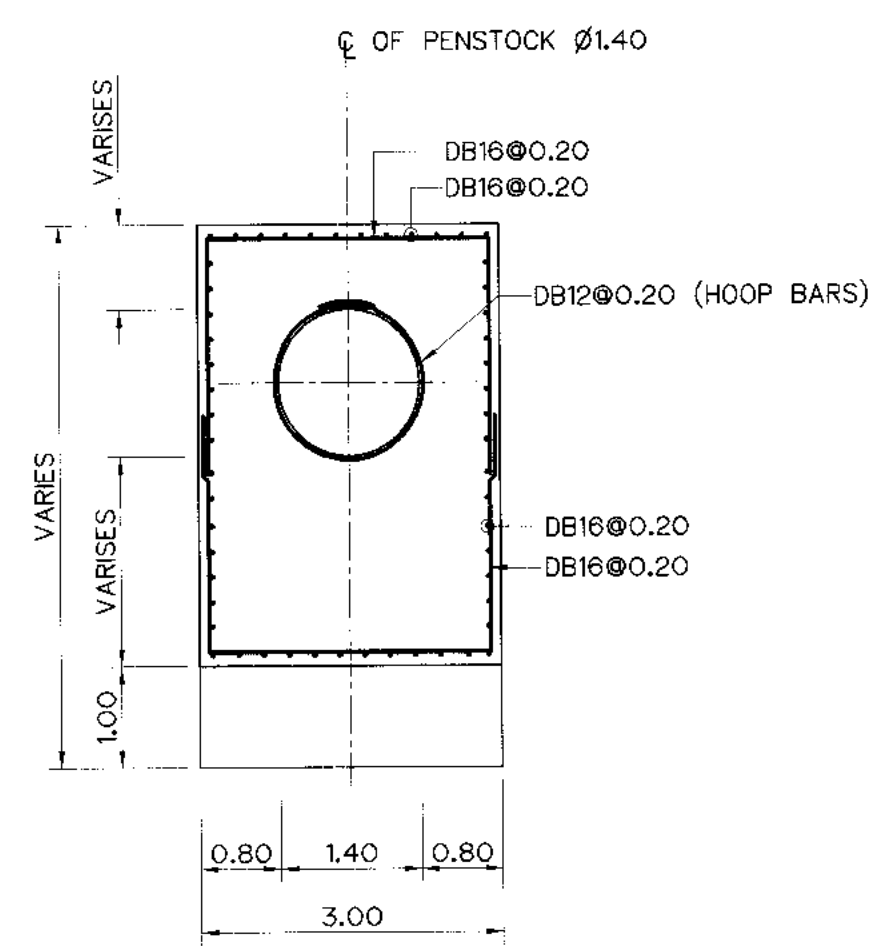

SECTION F-F
SCALE 1:75

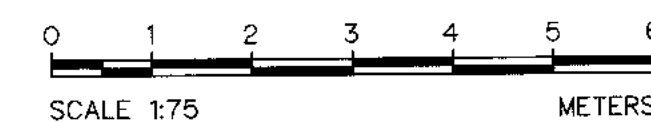

NOTES :


1. ALL DIMENSIONS AND ELEVATIONS (M.S.L.) ARE IN METERS, UNLESS OTHERWISE SHOWN.
2. SYMBOLS, ABBREVIATIONS AND GENERAL NOTES SEE DWG. NO. KLP-GN-03
3. THE ALIGNMENT OF THE HEADRACE AND RELATED STRUCTURES SHALL BE CHECK AND CORRECTED BY THE CONTRACTOR TO SUIT THE FIELD CONDITIONS AND SHALL BE SUBMITTED TO DEDE'S FIELD ENGINEER FOR APPROVAL

REFERENCE DRAWINGS :


1. PENSTOCK PLAN AND PROFILE, STA. 0+500 TO STA. 0+693.571 KLP-PS-01 TO 02

3				
2				
1				
NO.	DATE	REVISIONS	CHECKED	APPROVED


KINGDOM OF THAILAND Department of Alternative Energy Development and Efficiency MINISTRY OF ENERGY	
KLONG LAM PLOK HYDROPOWER PROJECT	
CIVIL WORKS AND TRANSMISSION LINE PENSTOCK THRUST BLOCK PLAN ,SECTIONS REINFORCEMENT DETAILS 1/5	
P&C MANAGEMENT CO.,LTD. DESIGNED <i>[Signature]</i> 28.0226 DRAWN <i>[Signature]</i> CHECKED <i>[Signature]</i> 28.0226 PROJECT MANAGER	REVIEWED <i>[Signature]</i> SUBMITTED <i>[Signature]</i> RECOMMENDED <i>[Signature]</i> APPROVED <i>[Signature]</i> DRAWING NO. KLP-PS-03 SHEET NO. 61 OF 110

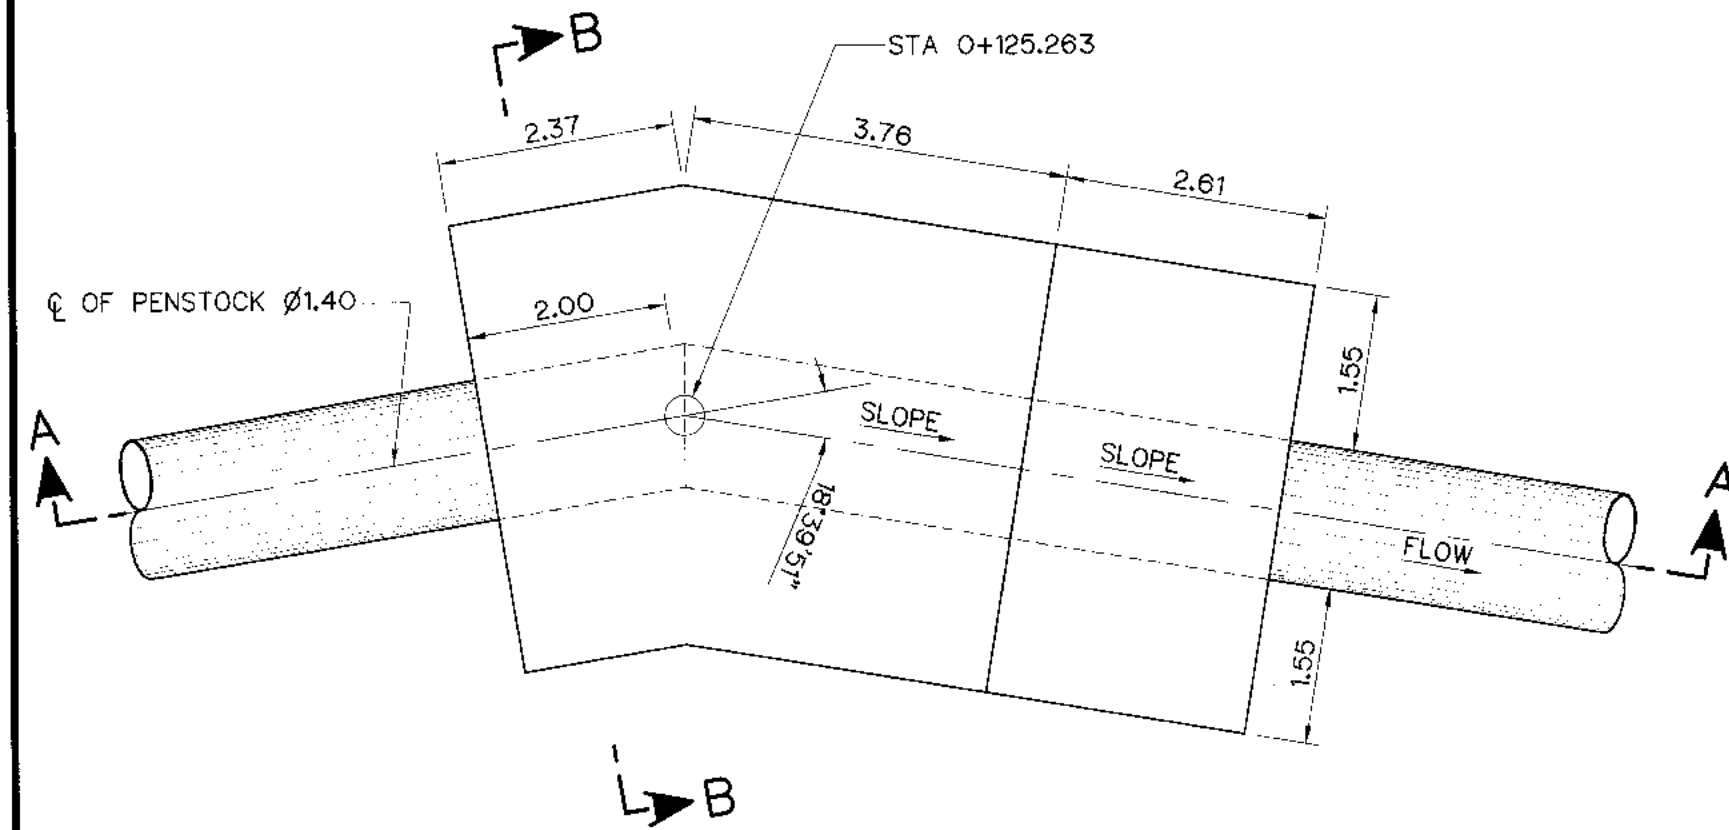


PLAN (THRUST BLOCK ④)
SCALE 1:75

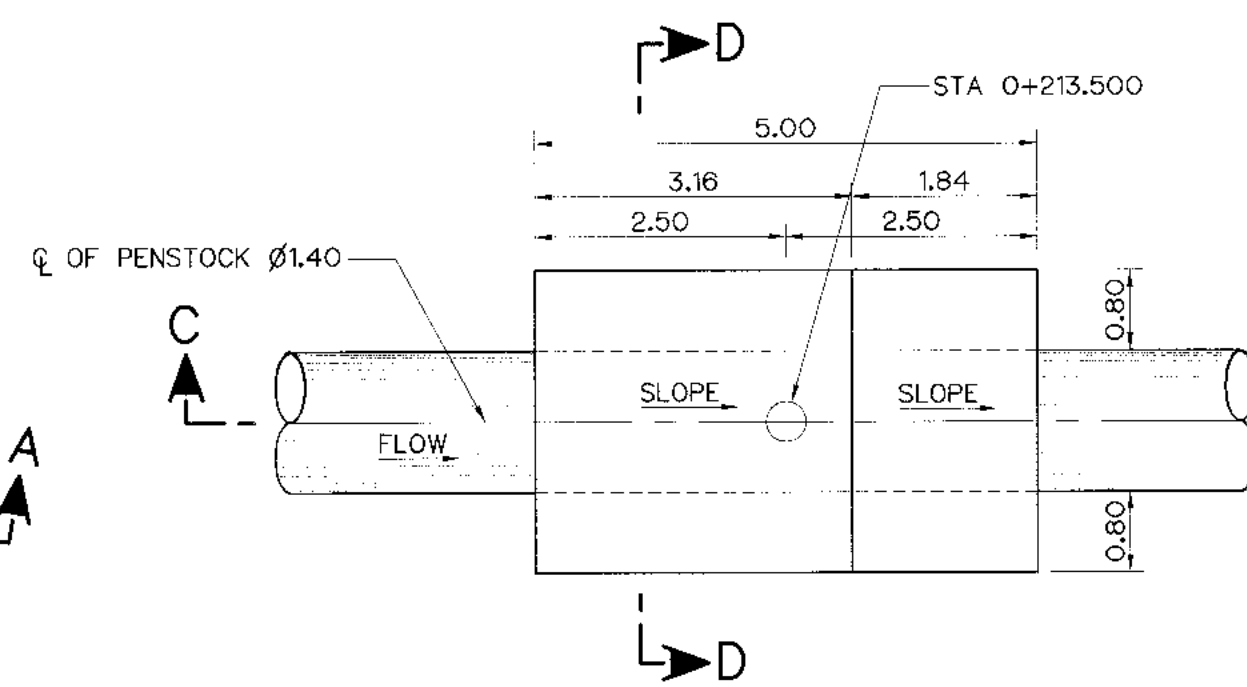


PLAN (THRUST BLOCK ⑤)
SCALE 1:75

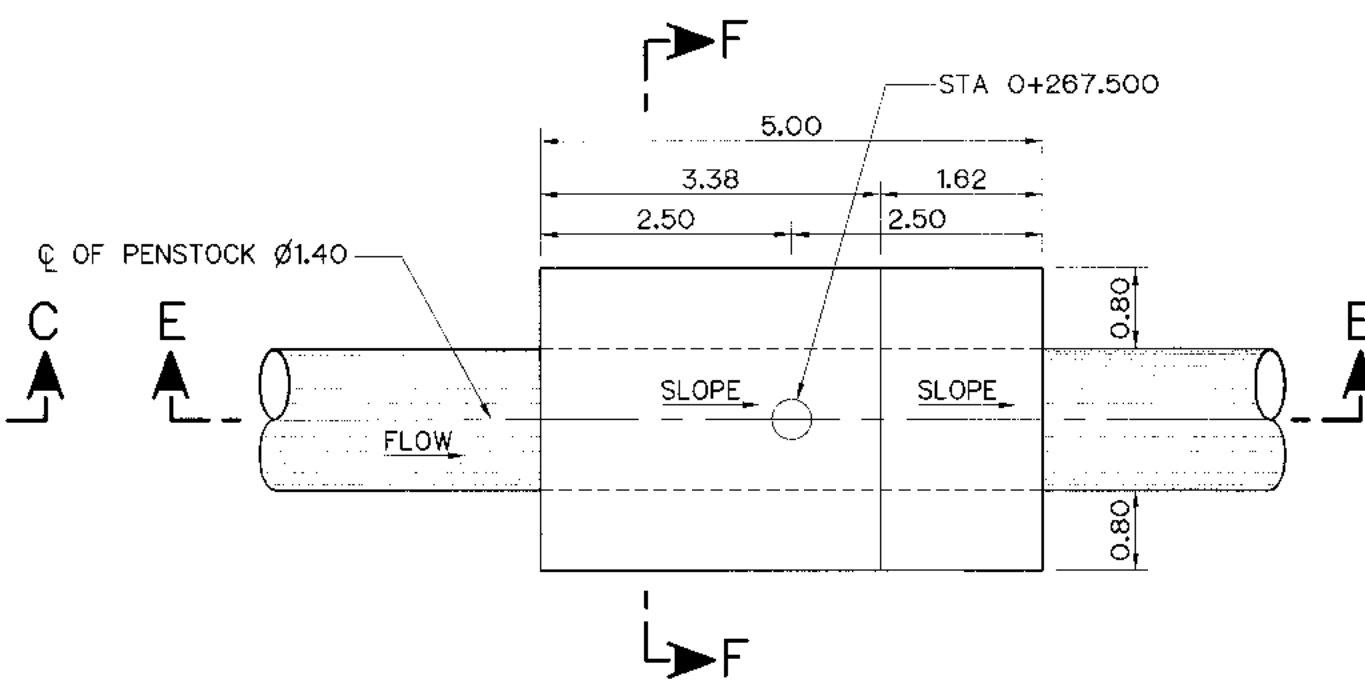


PLAN (THRUST BLOCK ⑥)
SCALE 1:75

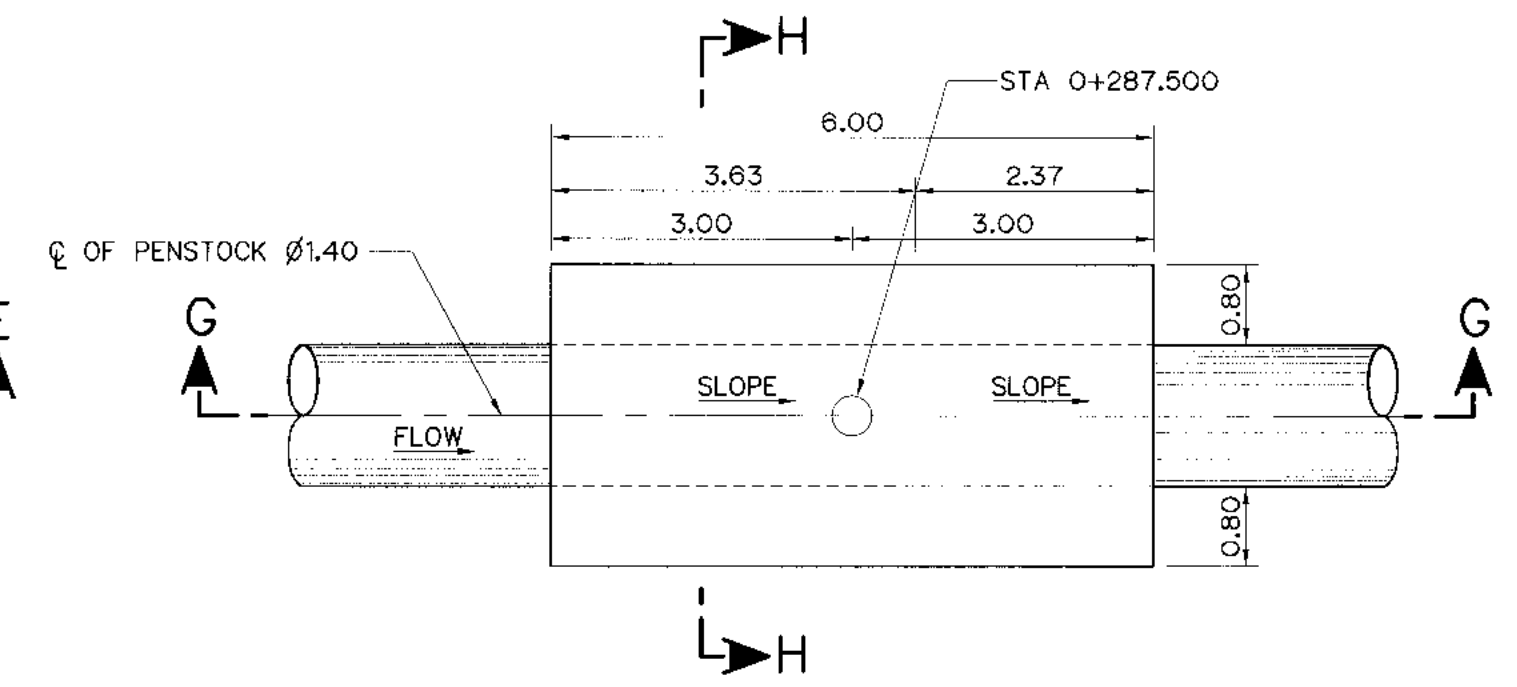


PLAN (THRUST BLOCK ⑦)
SCALE 1:75

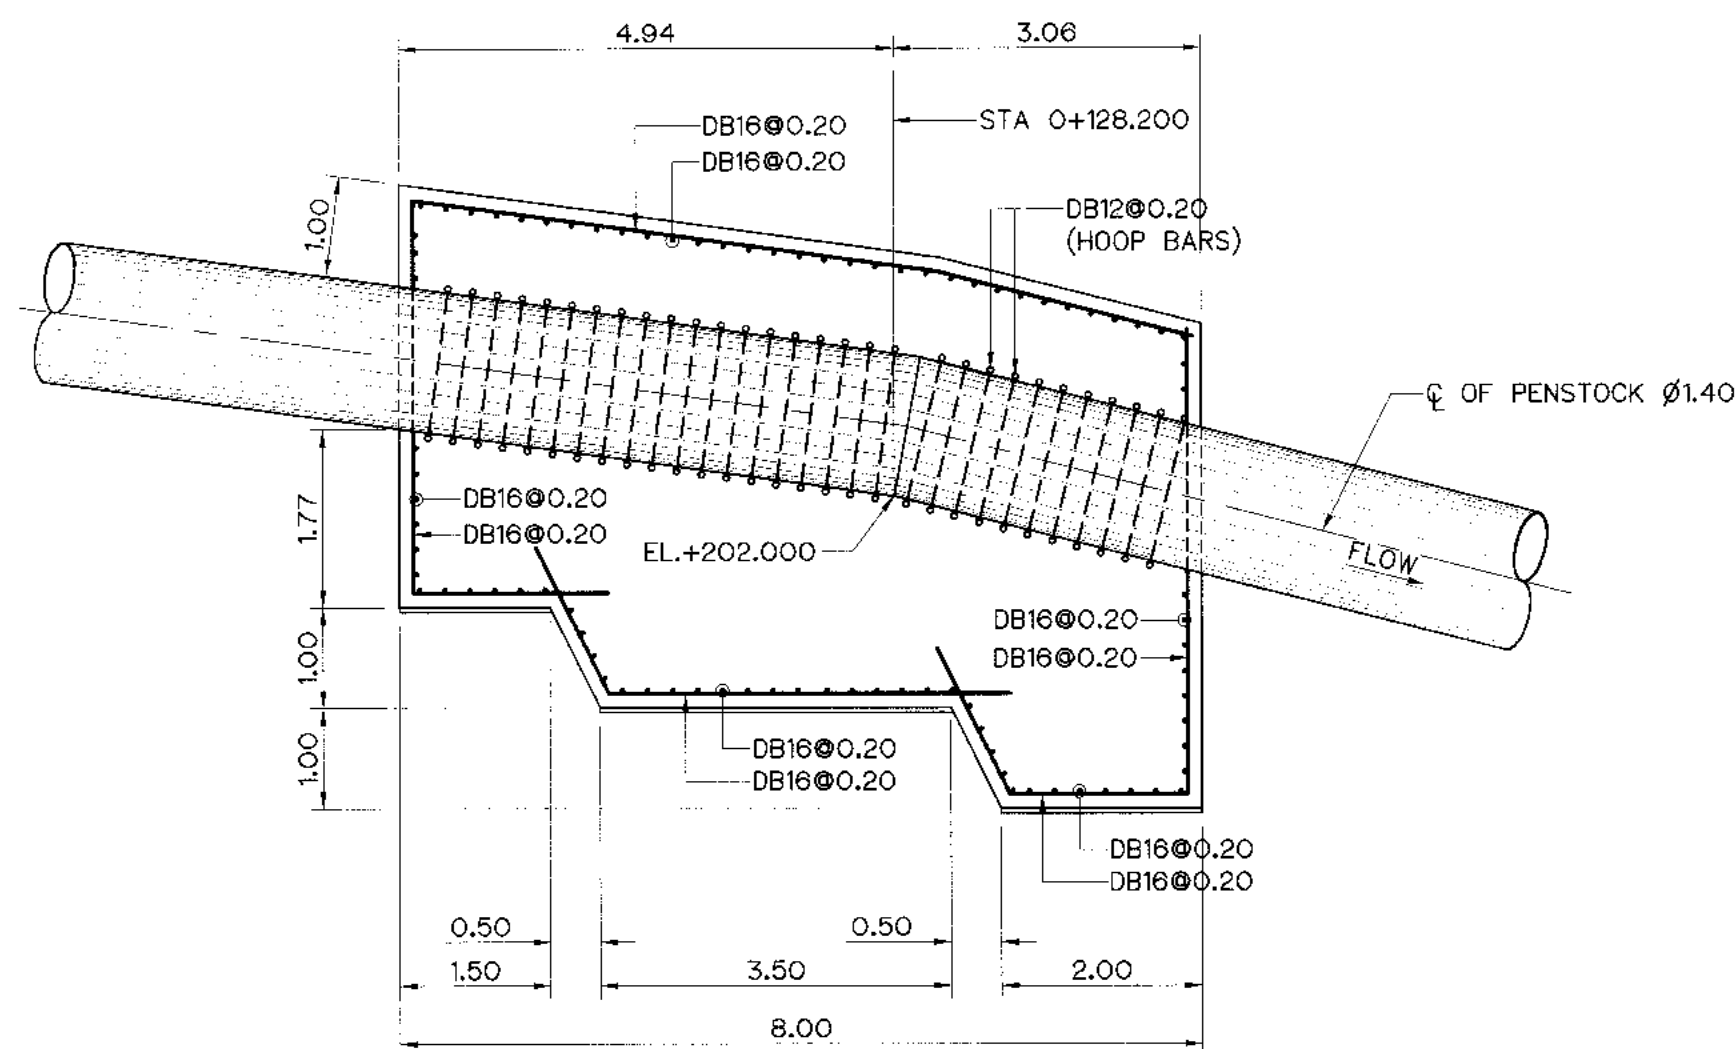


SECTION A-A
SCALE 1:75

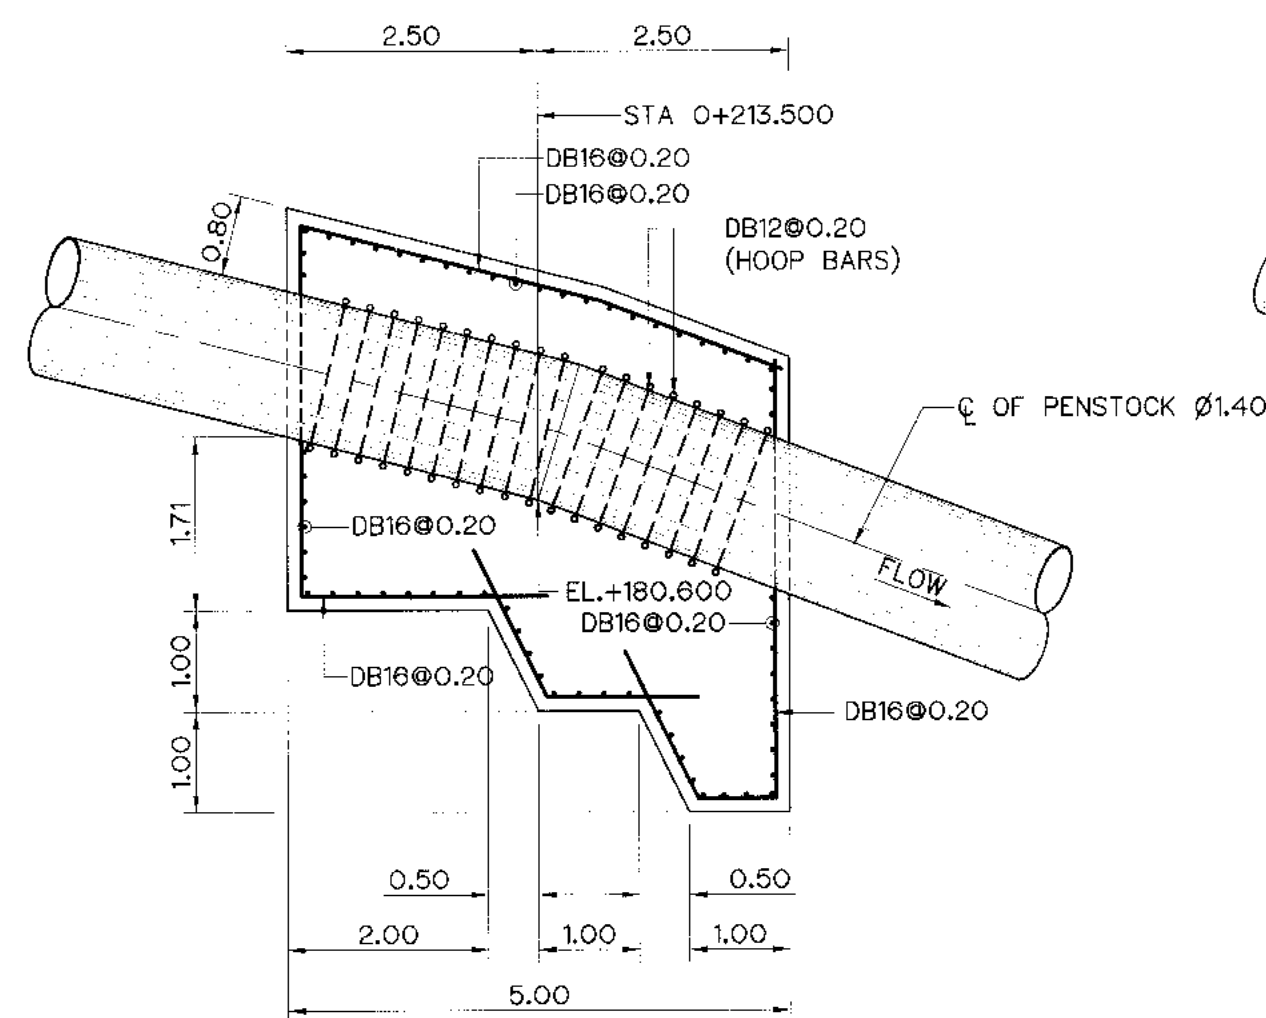


SECTION C-C
SCALE 1:75

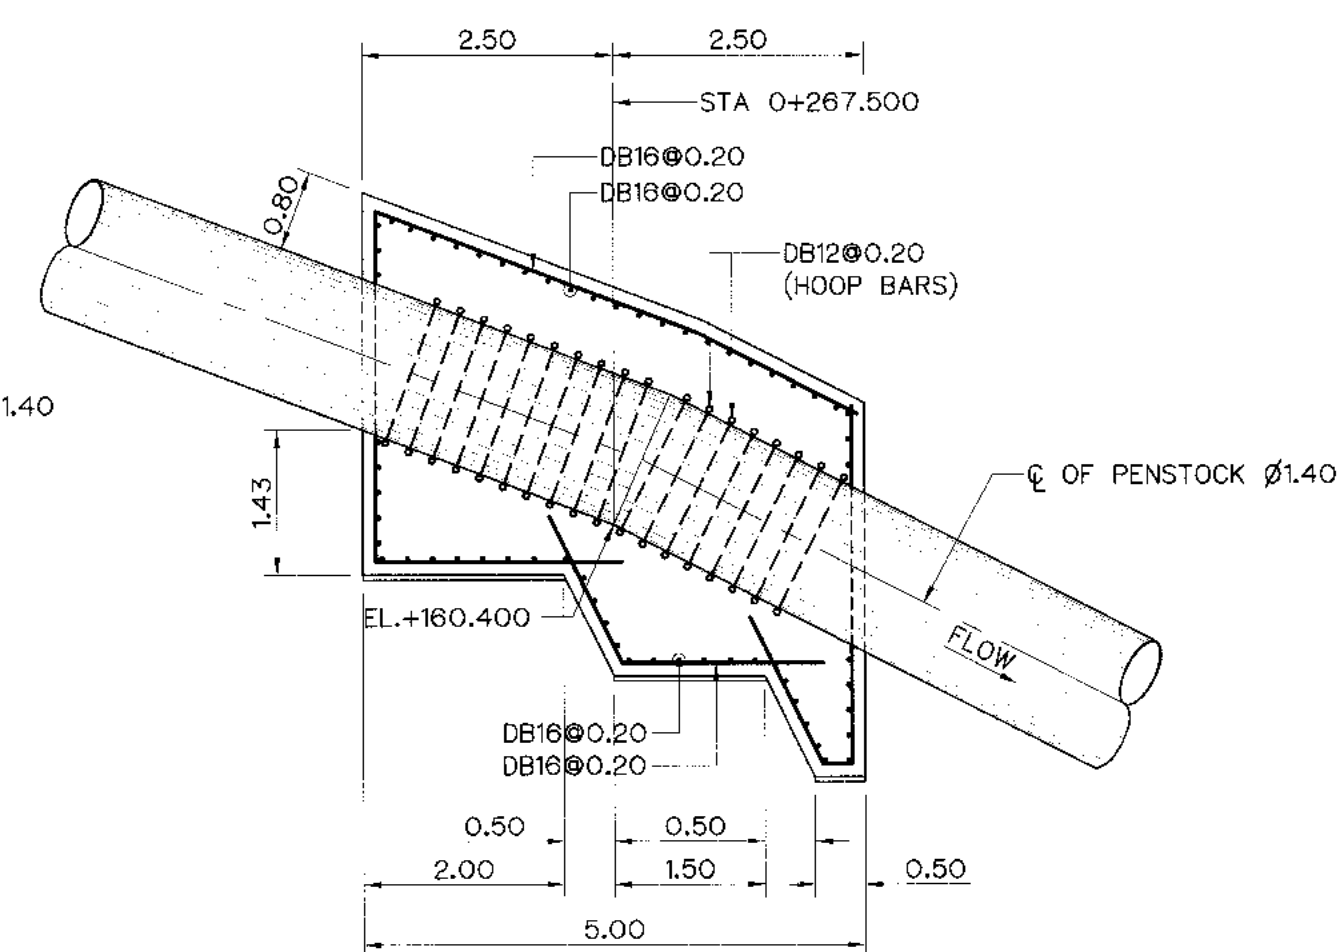


SECTION E-E
SCALE 1:75

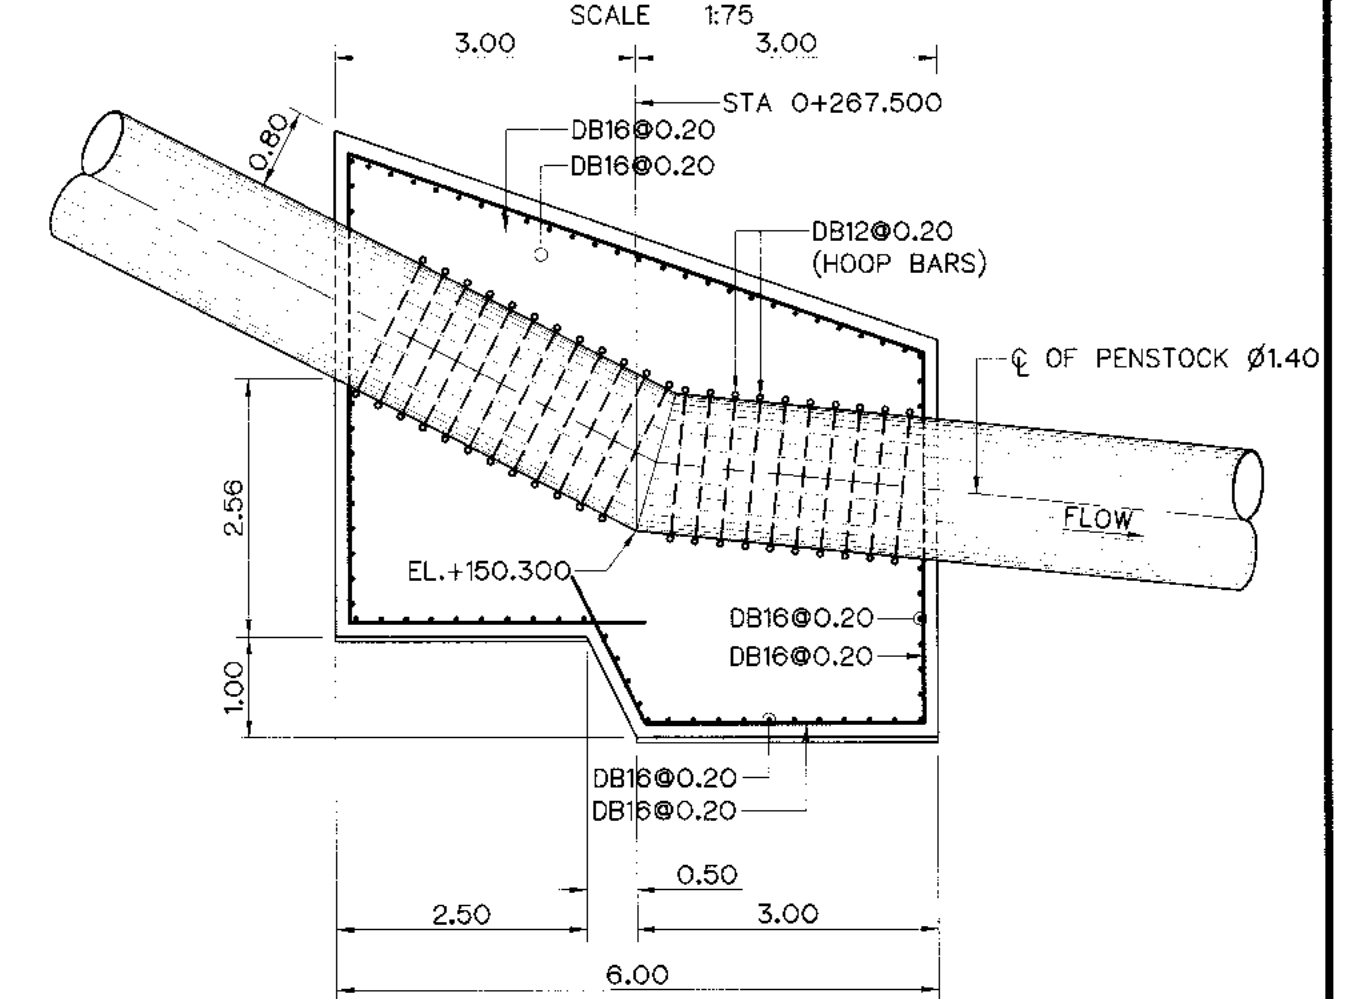


SECTION G-G
SCALE 1:75

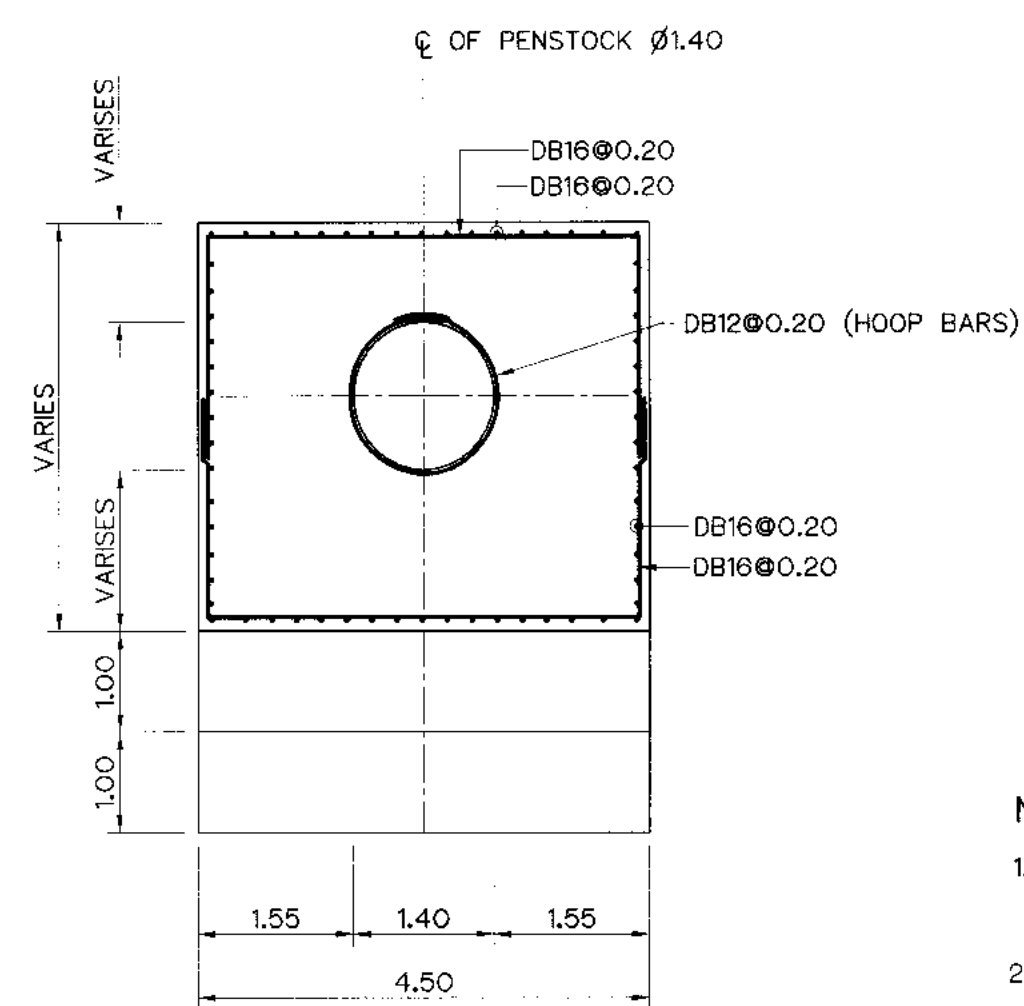


SECTION B-B
SCALE 1:75

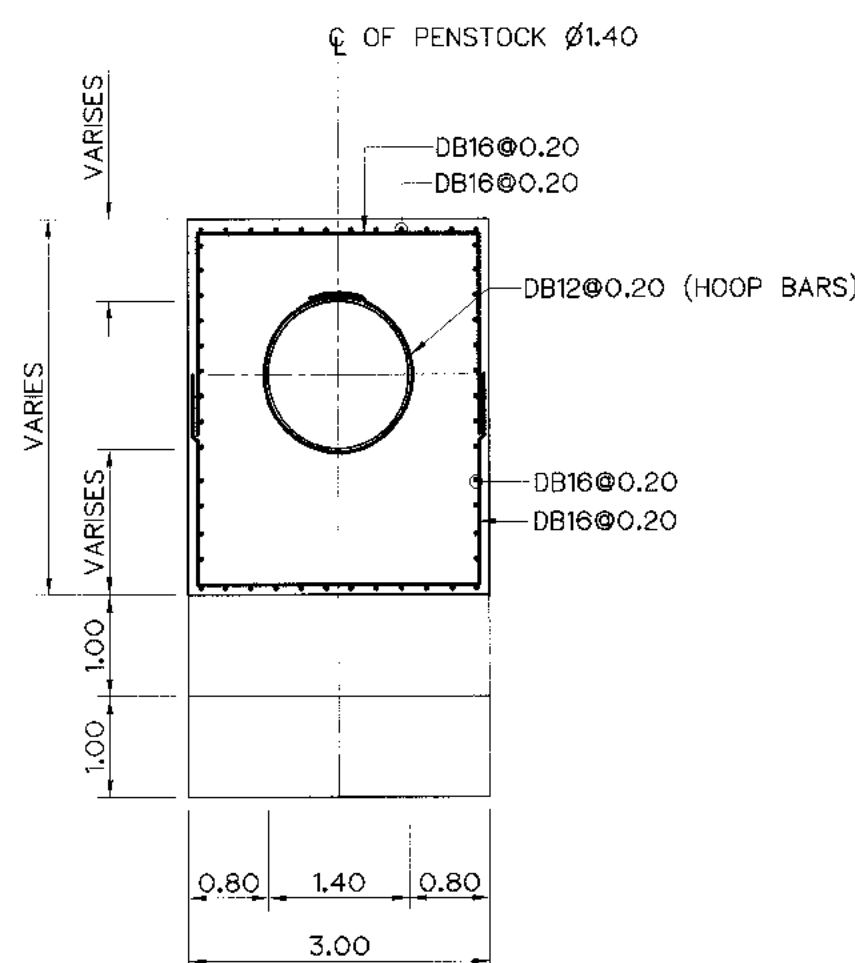

SECTION D-D
SCALE 1:75

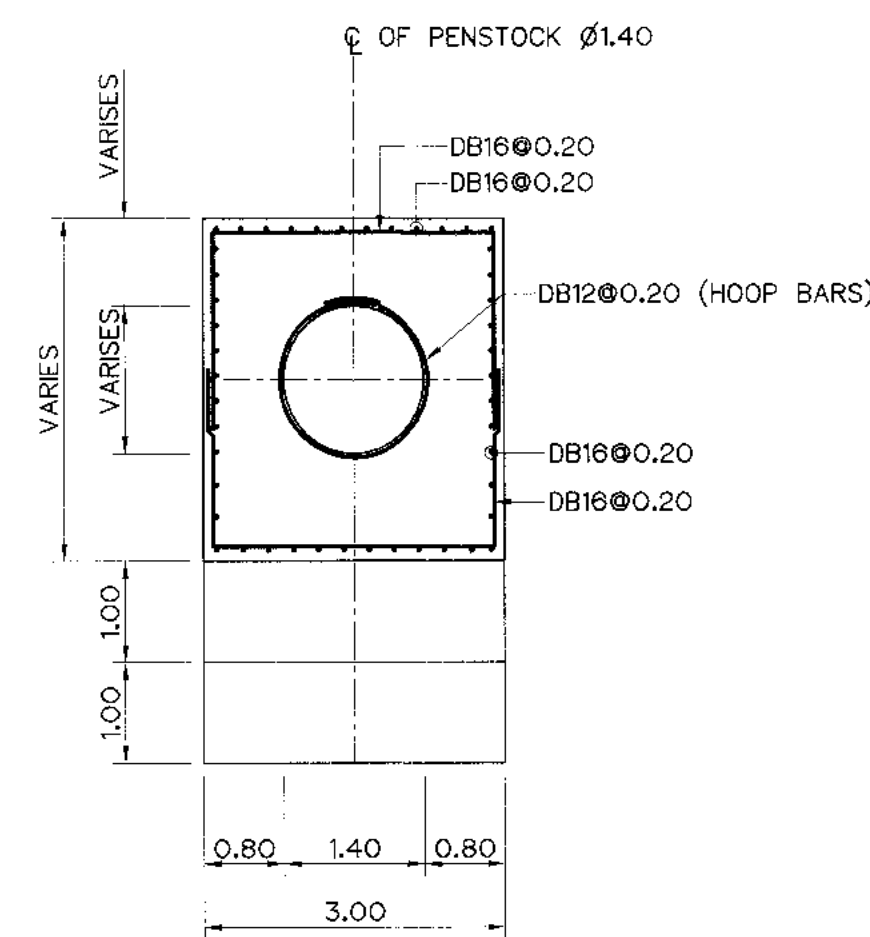

SECTION F-F
SCALE 1:75

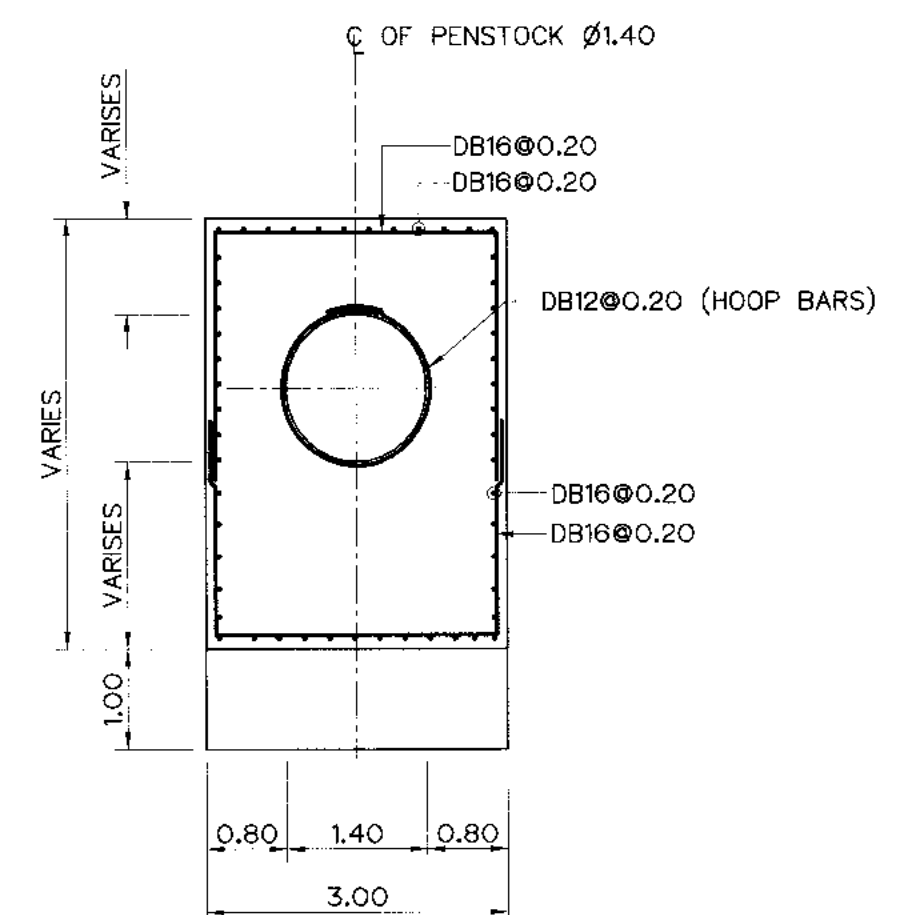


SECTION H-H
SCALE 1:75

NOTES :

1. ALL DIMENSIONS AND ELEVATIONS (M.S.L.) ARE IN METERS, UNLESS OTHERWISE SHOWN.
2. SYMBOLS, ABBREVIATIONS AND GENERAL NOTES SEE DWG. NO. KLP-GN-03
3. THE ALIGNMENT OF THE HEADRACE AND RELATED STRUCTURES SHALL BE CHECK AND CORRECTED BY THE CONTRACTOR TO SUIT THE FIELD CONDITIONS AND SHALL BE SUBMITTED TO DEDE'S FIELD ENGINEER FOR APPROVAL













REFERENCE DRAWINGS :

1. PENSTOCK PLAN AND PROFILE, STA. 0+000 TO STA. 0+693.571 KLP-PS-01 TO 02

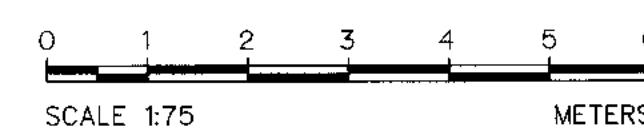


3					
2					
1					
NO.	DATE	REVISIONS	CHECKED	APPROVED	
					CONSULTANTS
					DEDE

KINGDOM OF THAILAND Department of Alternative Energy Development and Efficiency MINISTRY OF ENERGY					
KLONG LAM PLOK HYDROPOWER PROJECT					
CIVIL WORKS AND TRANSMISSION LINE					
PENSTOCK					
THRUST BLOCK PLAN ,SECTIONS REINFORCEMENT DETAILS 2/5					
P&C MANAGEMENT CO.,LTD.			Department of Alternative Energy Development and Efficiency MINISTRY OF ENERGY		
DESIGNED 11/29/74 05-2226			REVIEWED		
DRAWN			SUBMITTED		
CHECKED			RECOMMENDED		
PROJECT MANAGER			APPROVED		
08/03/2559			DRAWING NO.		
			KLP-PS-04		
			SHEET NO.		
			62 OF 110		

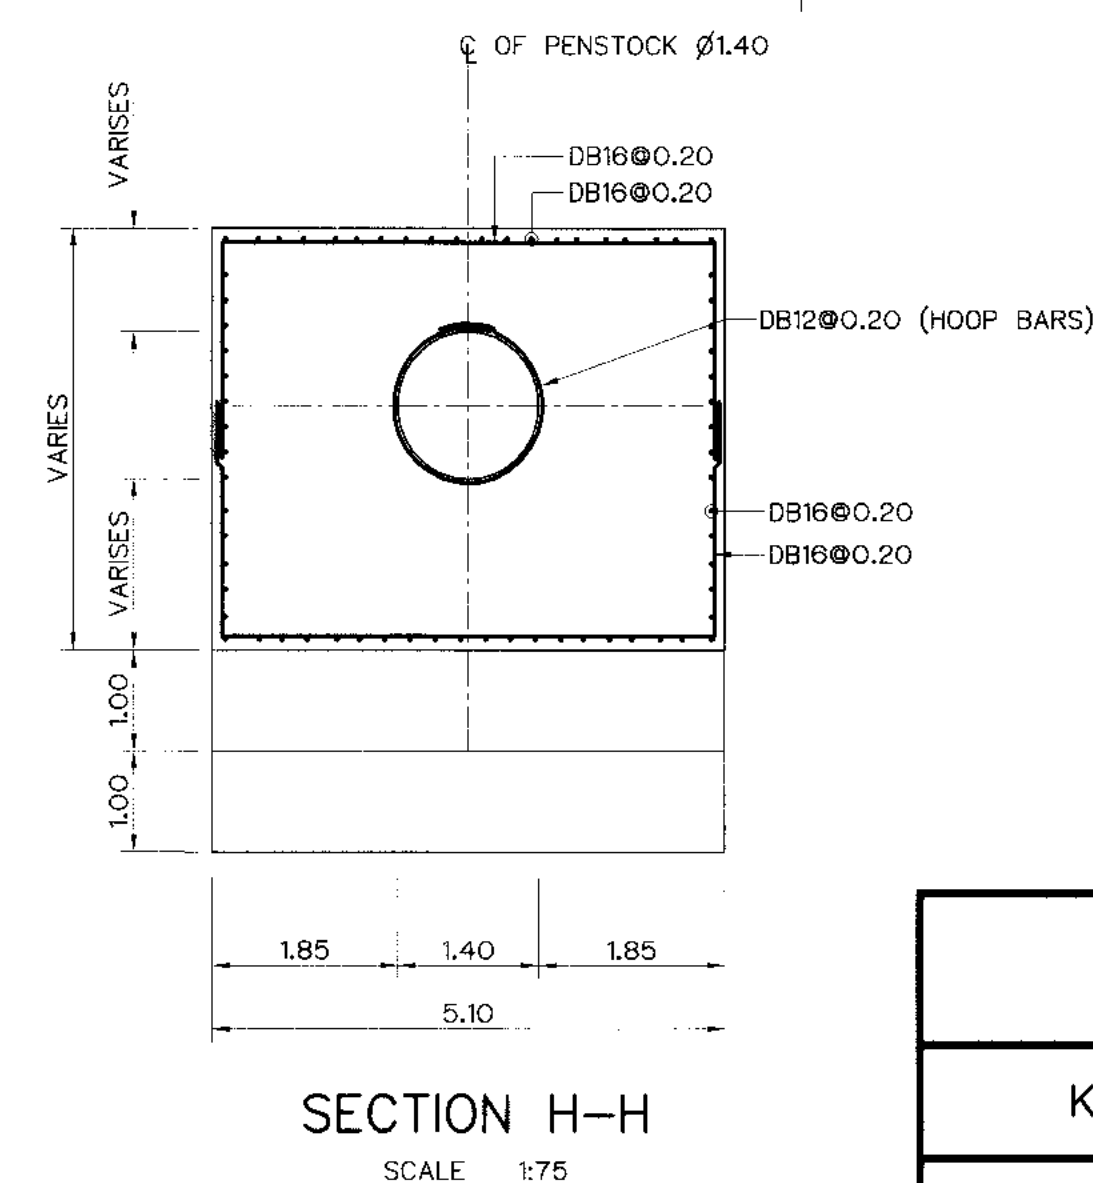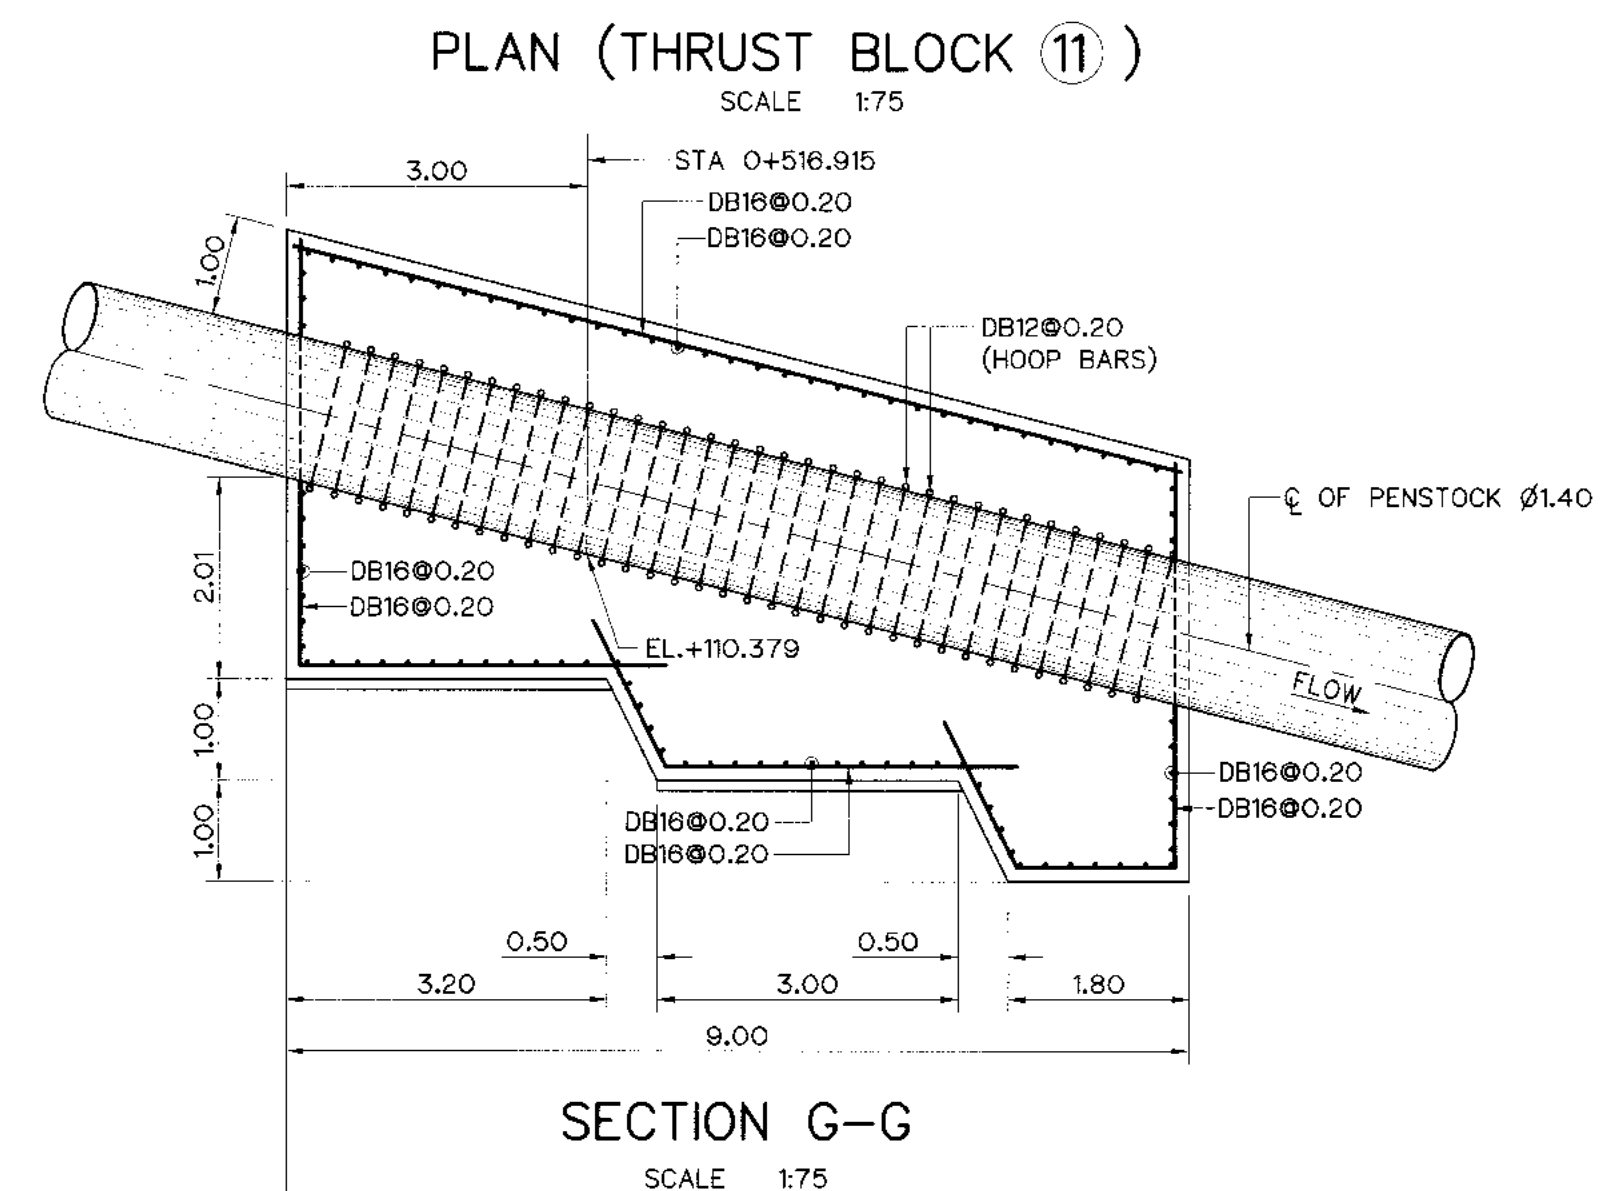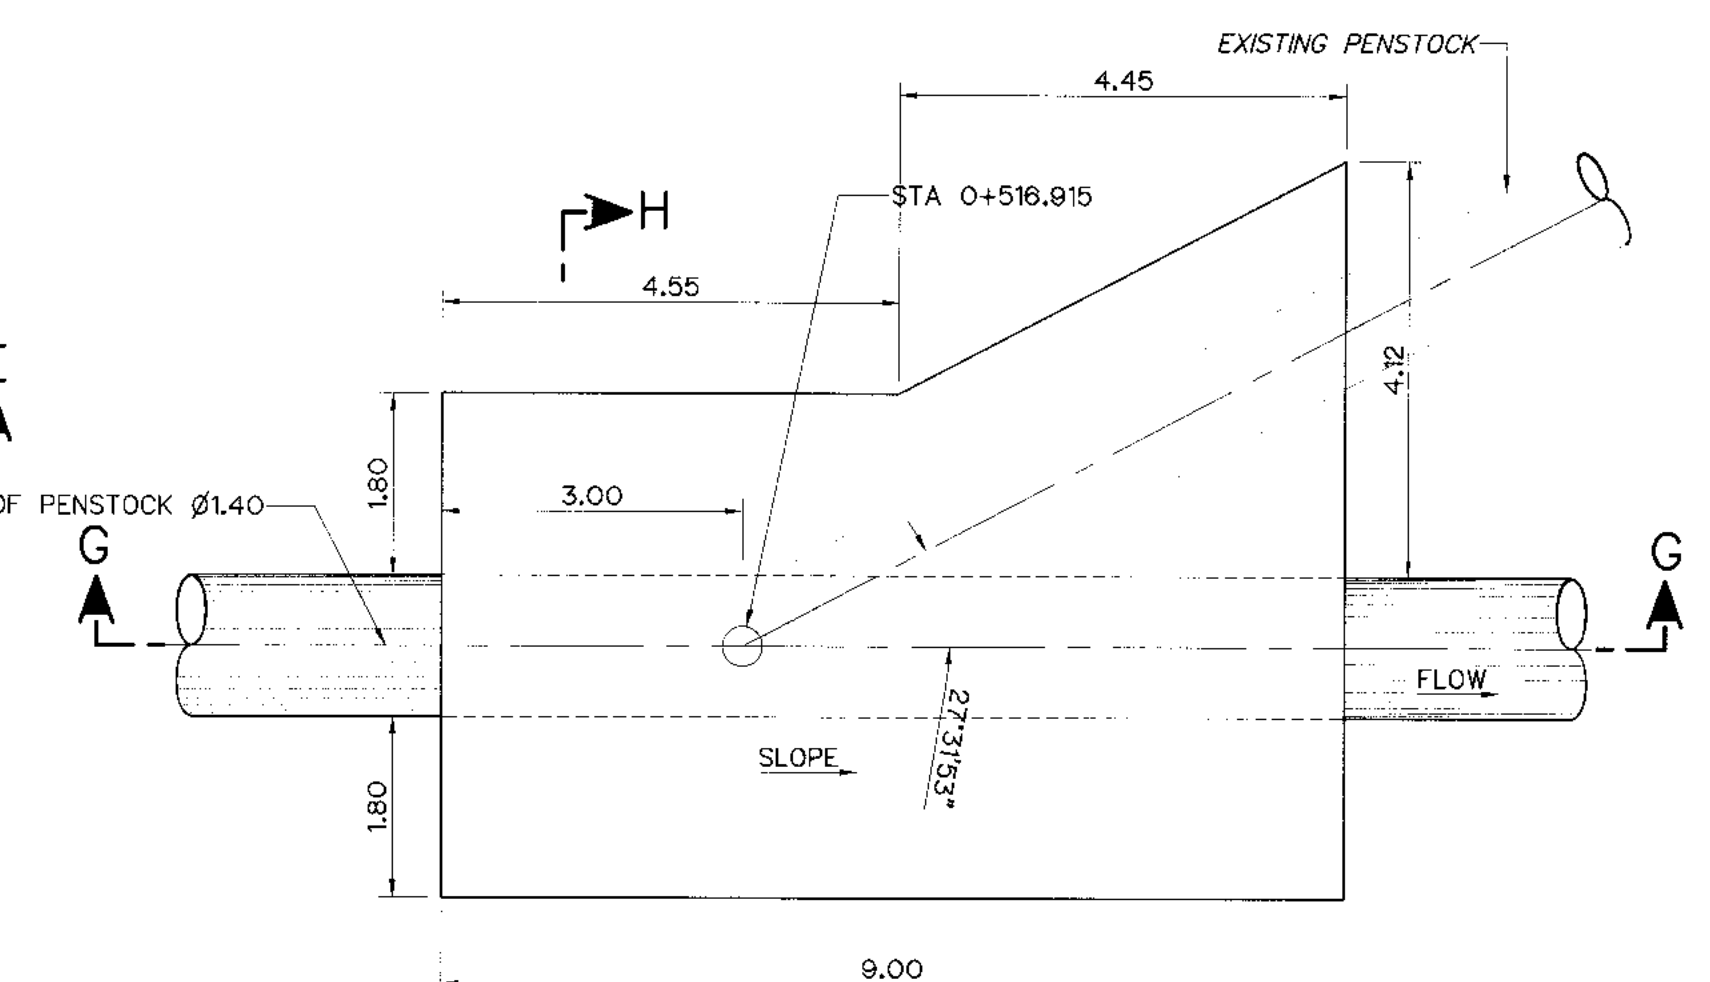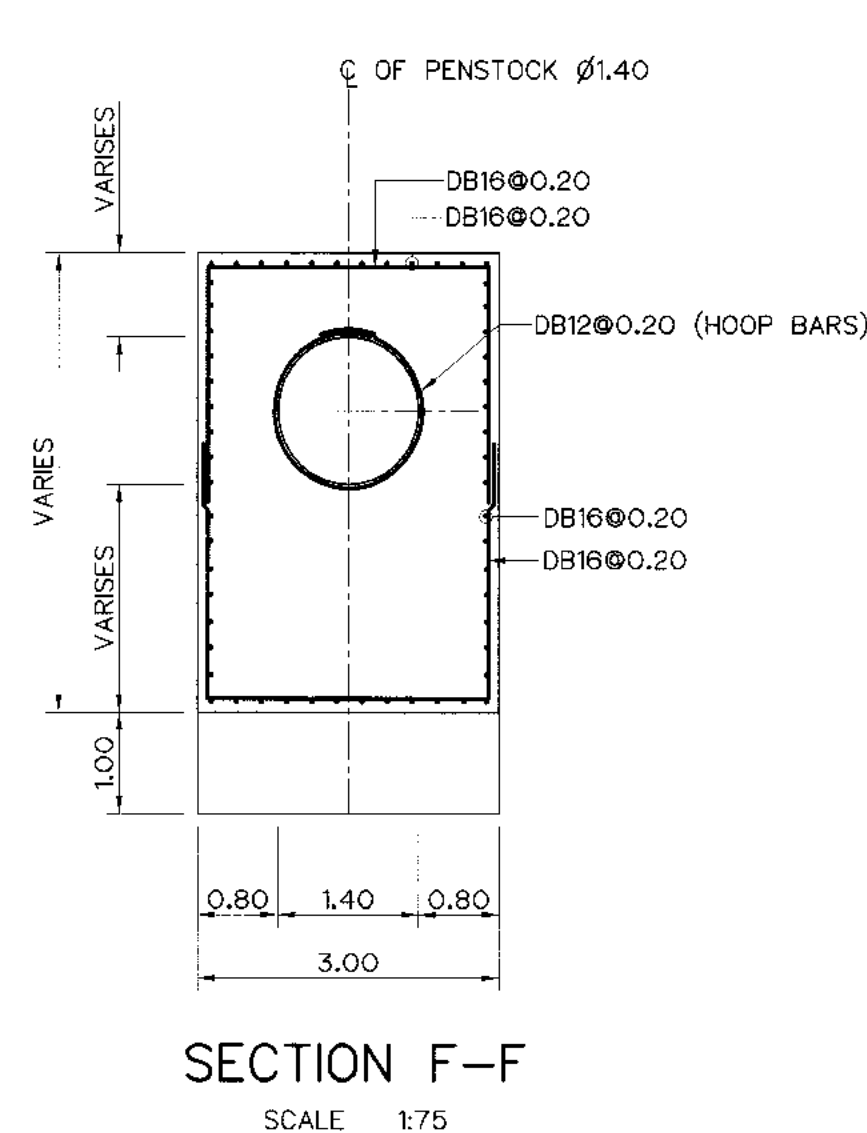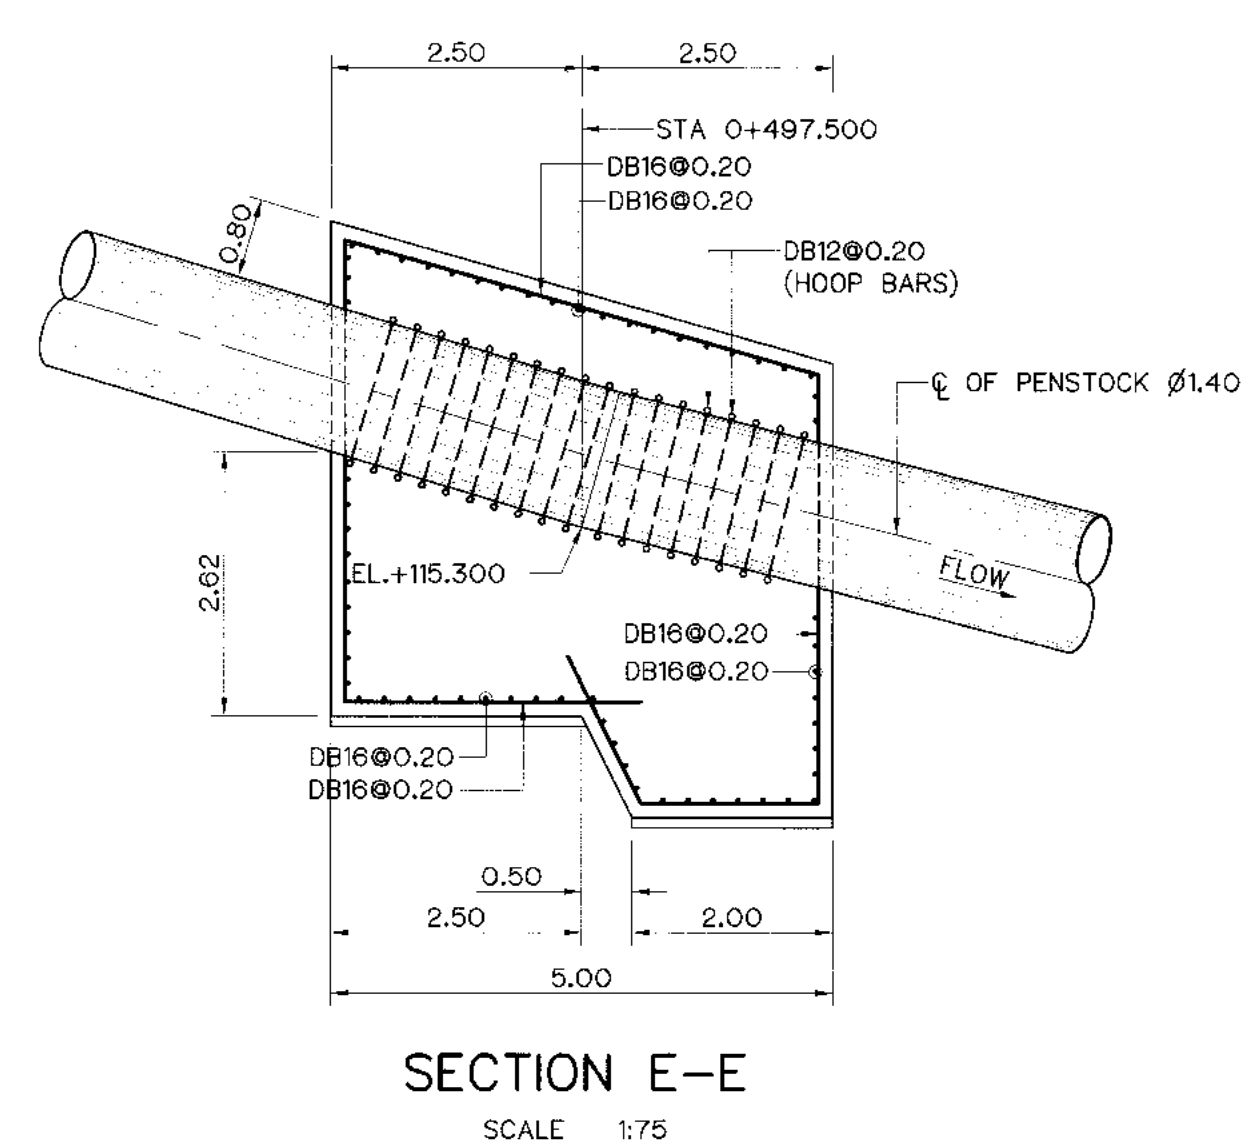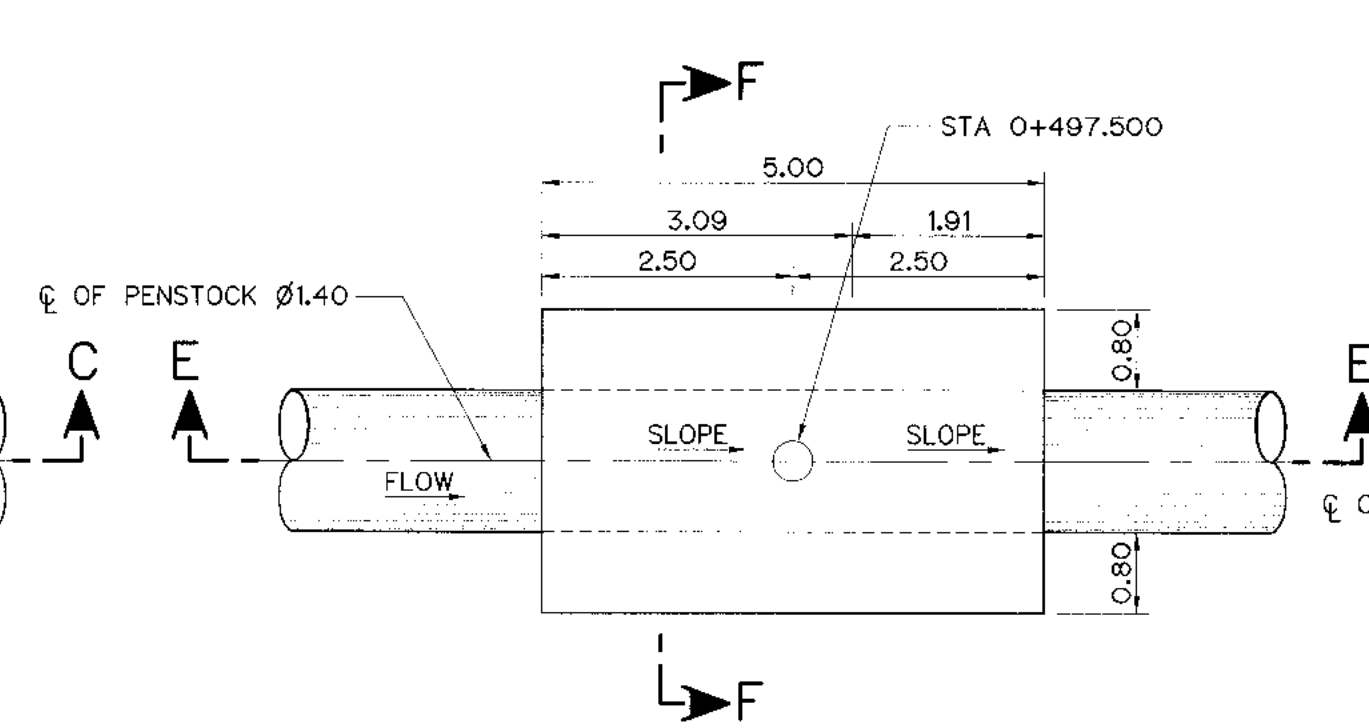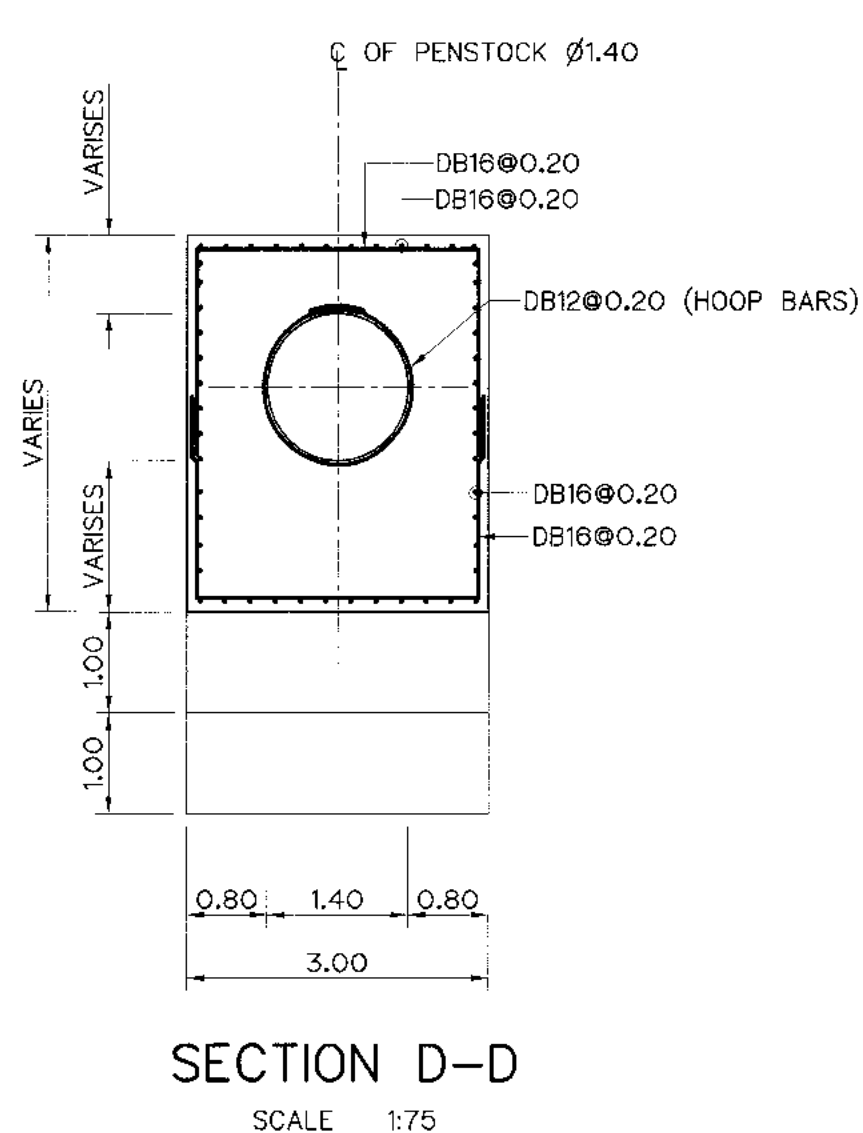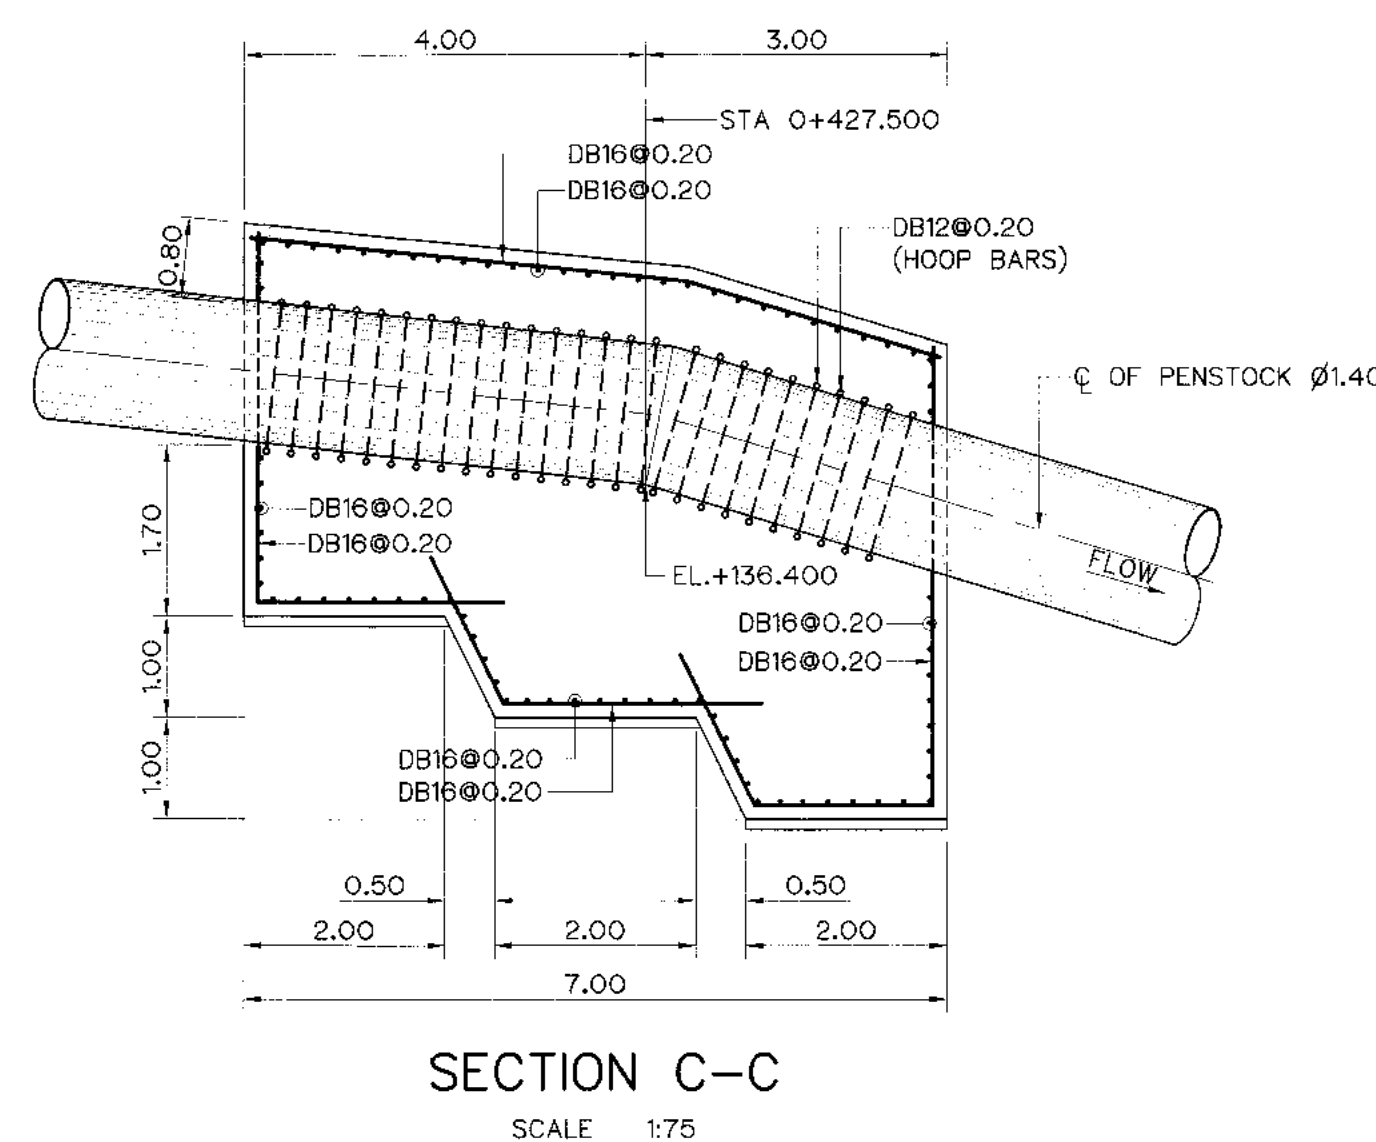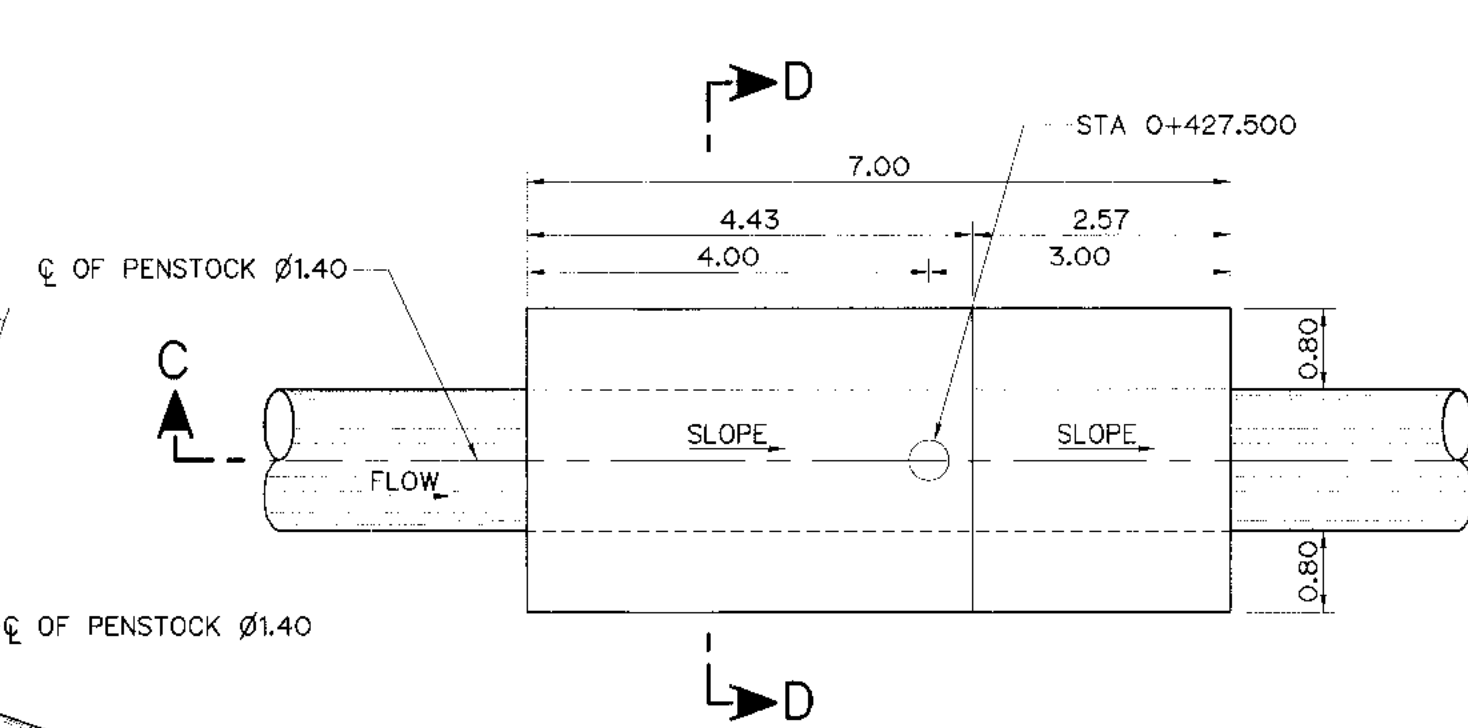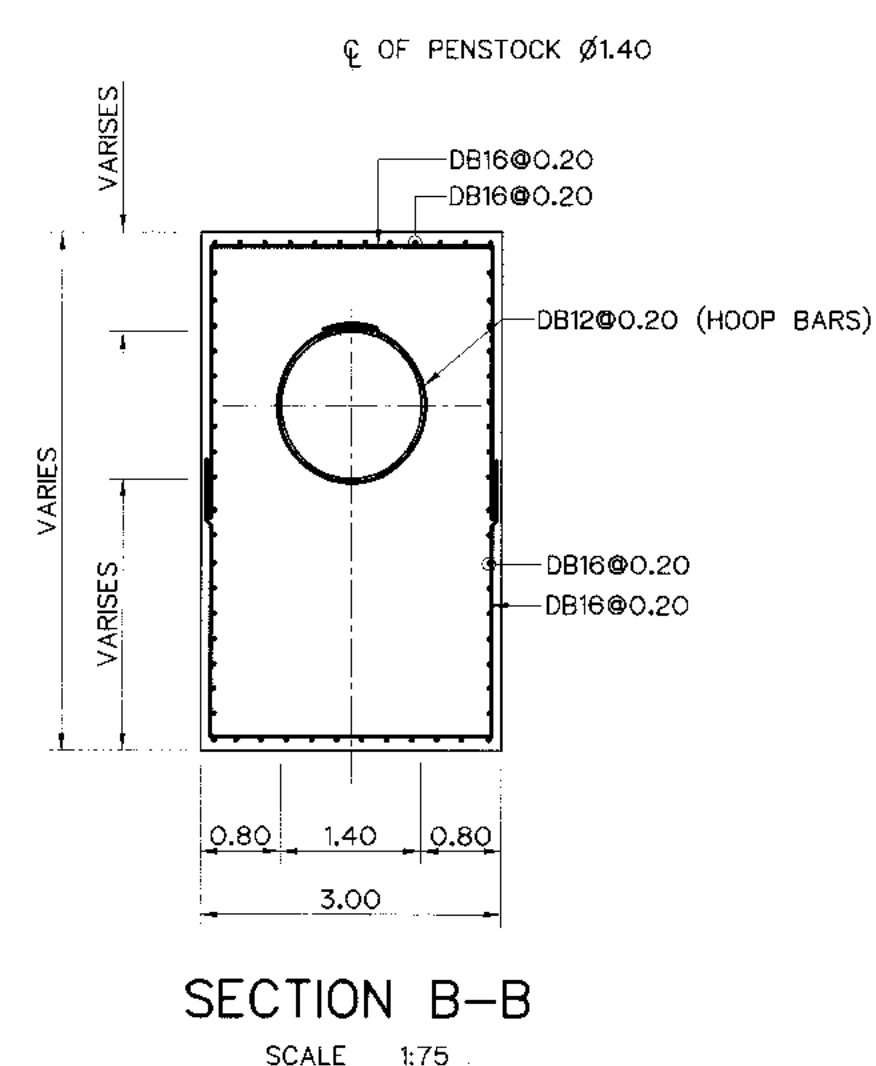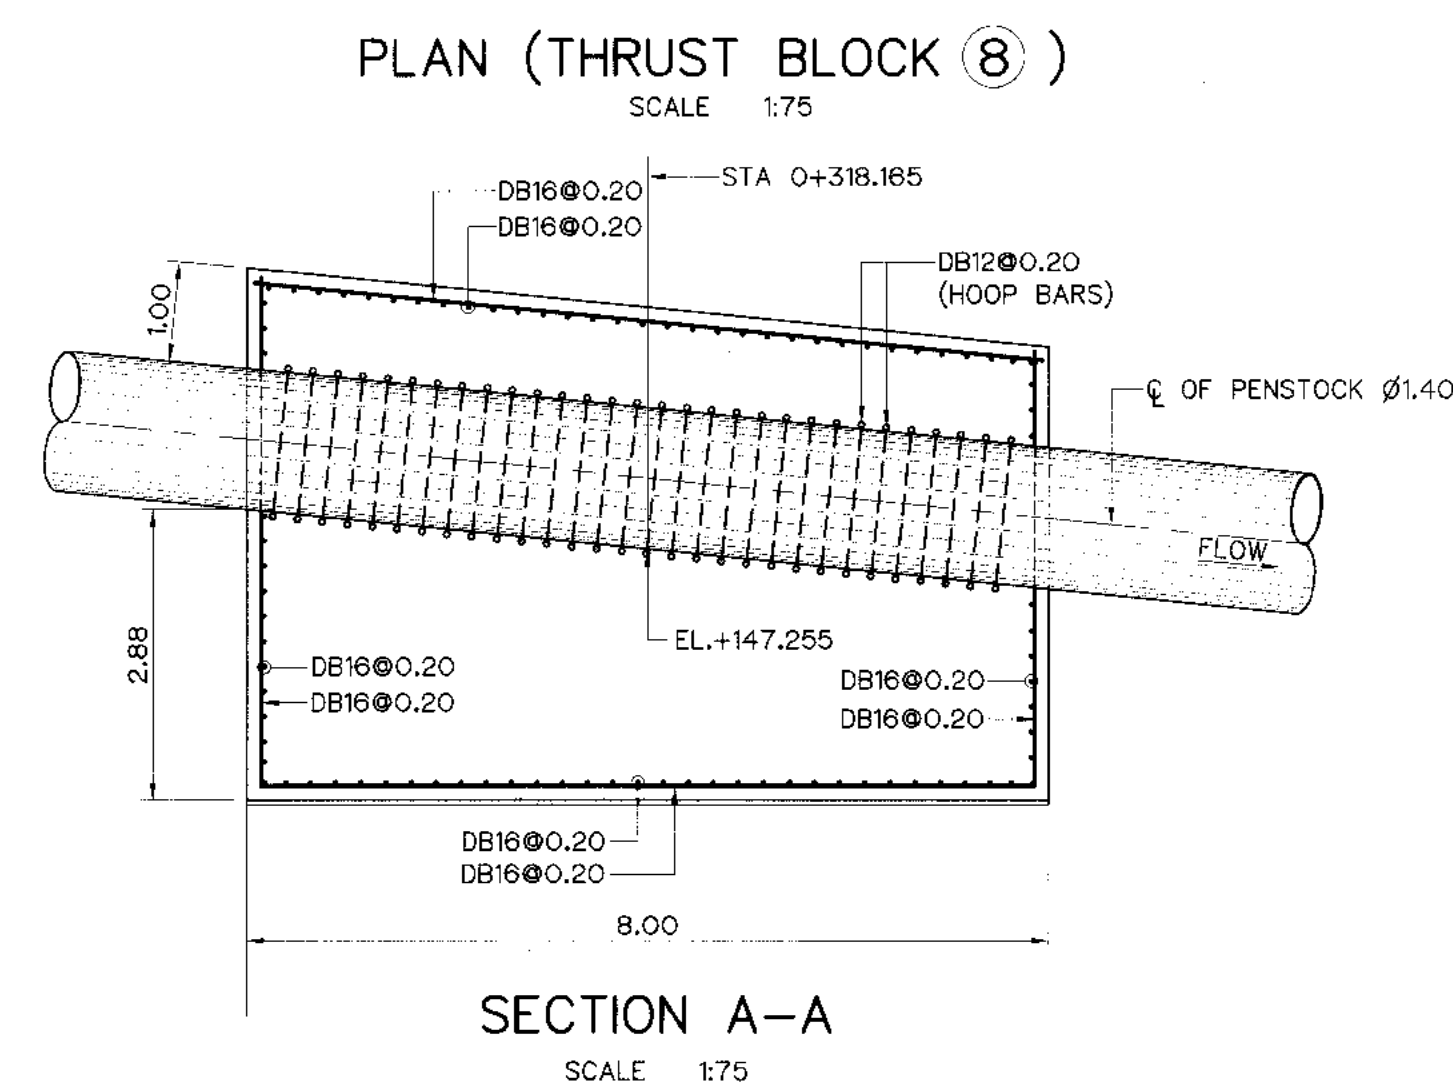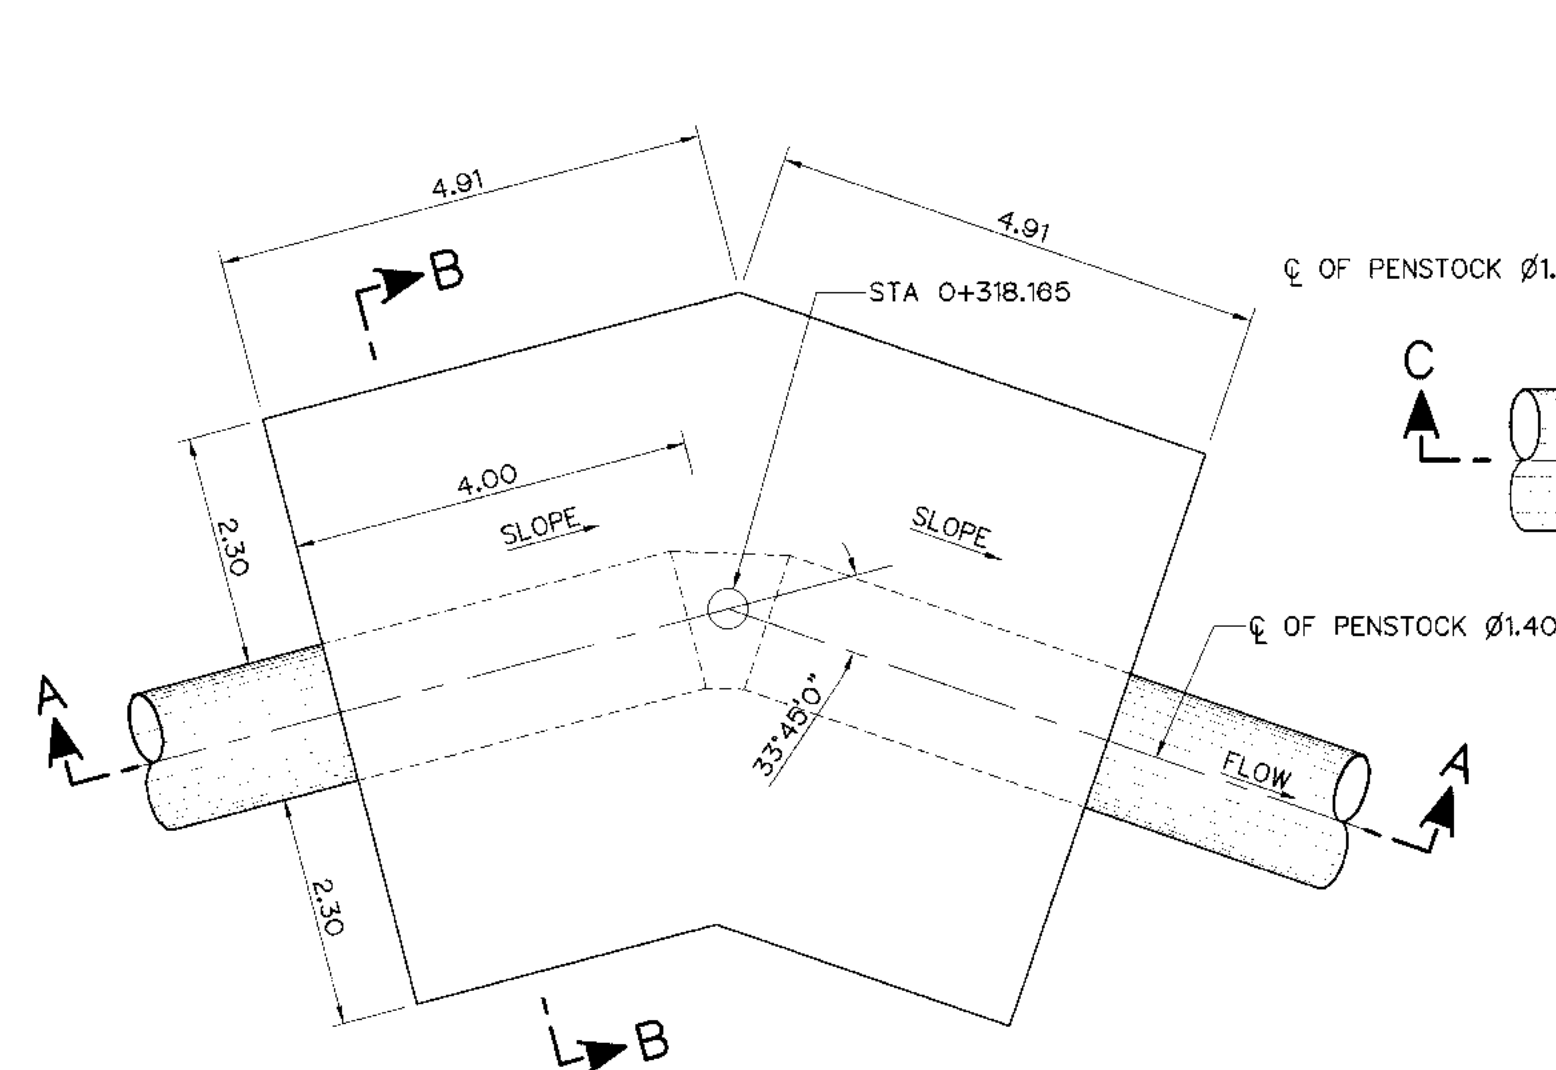












- NOTES :**
1. ALL DIMENSIONS AND ELEVATIONS (M.S.L.) ARE IN METERS. UNLESS OTHERWISE SHOWN.
 2. RELATIONS, ABBREVIATIONS AND GENERAL NOTES SEE DWG. NO. KLP-GN-03
 3. THE ALIGNMENT OF THE HEADRACE AND RELATED STRUCTURES SHALL BE CHECK AND CORRECTED BY THE CONTRACTOR TO SUIT THE FIELD CONDITIONS AND SHALL BE SUBMITTED TO DEDE'S FIELD ENGINEER FOR APPROVAL

- REFERENCE DRAWINGS :
1. PENSTOCK PLAN AND PROFILE, STA. 0+500 TO STA. 0+693.571 KLP-PS-01 TO 02

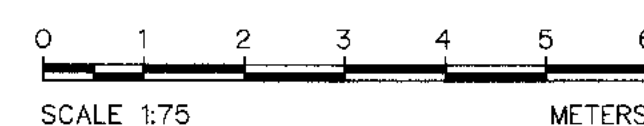

3				
2				
1				
NO.	DATE	REVISIONS	CHECKED	APPROVED
	CONSULTANTS		DEDE	

	KINGDOM OF THAILAND Department of Alternative Energy Development and Efficiency MINISTRY OF ENERGY
KLONG LAM PLOK HYDROPOWER PROJECT	
CIVIL WORKS AND TRANSMISSION LINE	
PENSTOCK	
THRUST BLOCK PLAN ,SECTIONS REINFORCEMENT DETAILS 3/5	
 P&C MANAGEMENT CO.,LTD.	 Department of Alternative Energy Development and Efficiency MINISTRY OF ENERGY
DESIGNED <i>TH</i> 211.29074 <i>DT</i> 261.6226	REVIEWED <i>[Signature]</i>
DRAWN <i>[Signature]</i>	SUBMITTED <i>Chait</i>
CHECKED <i>[Signature]</i> 261.6226	RECOMMENDED <i>[Signature]</i>
<i>DT</i> PROJECT MANAGER	APPROVED <i>P. Harnall</i> DRAWING NO. KLP-PS-05
DATE	SHEET NO. 63 of 110

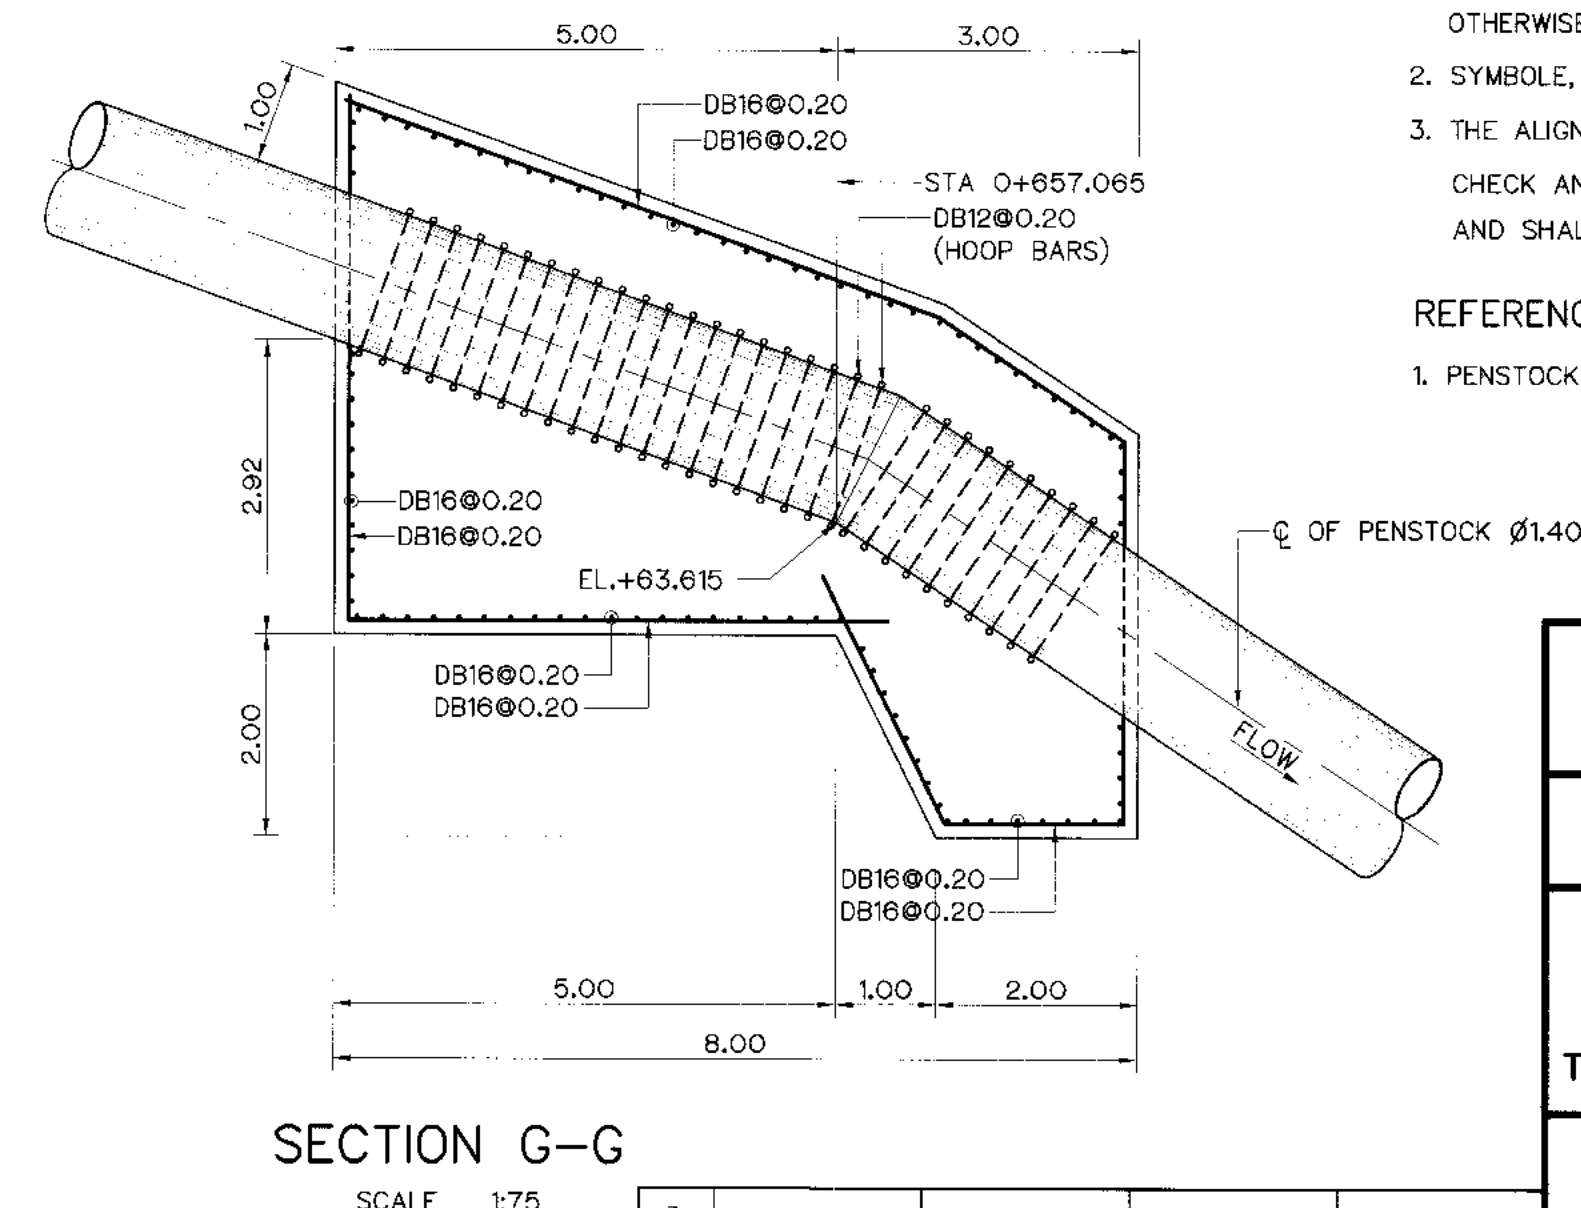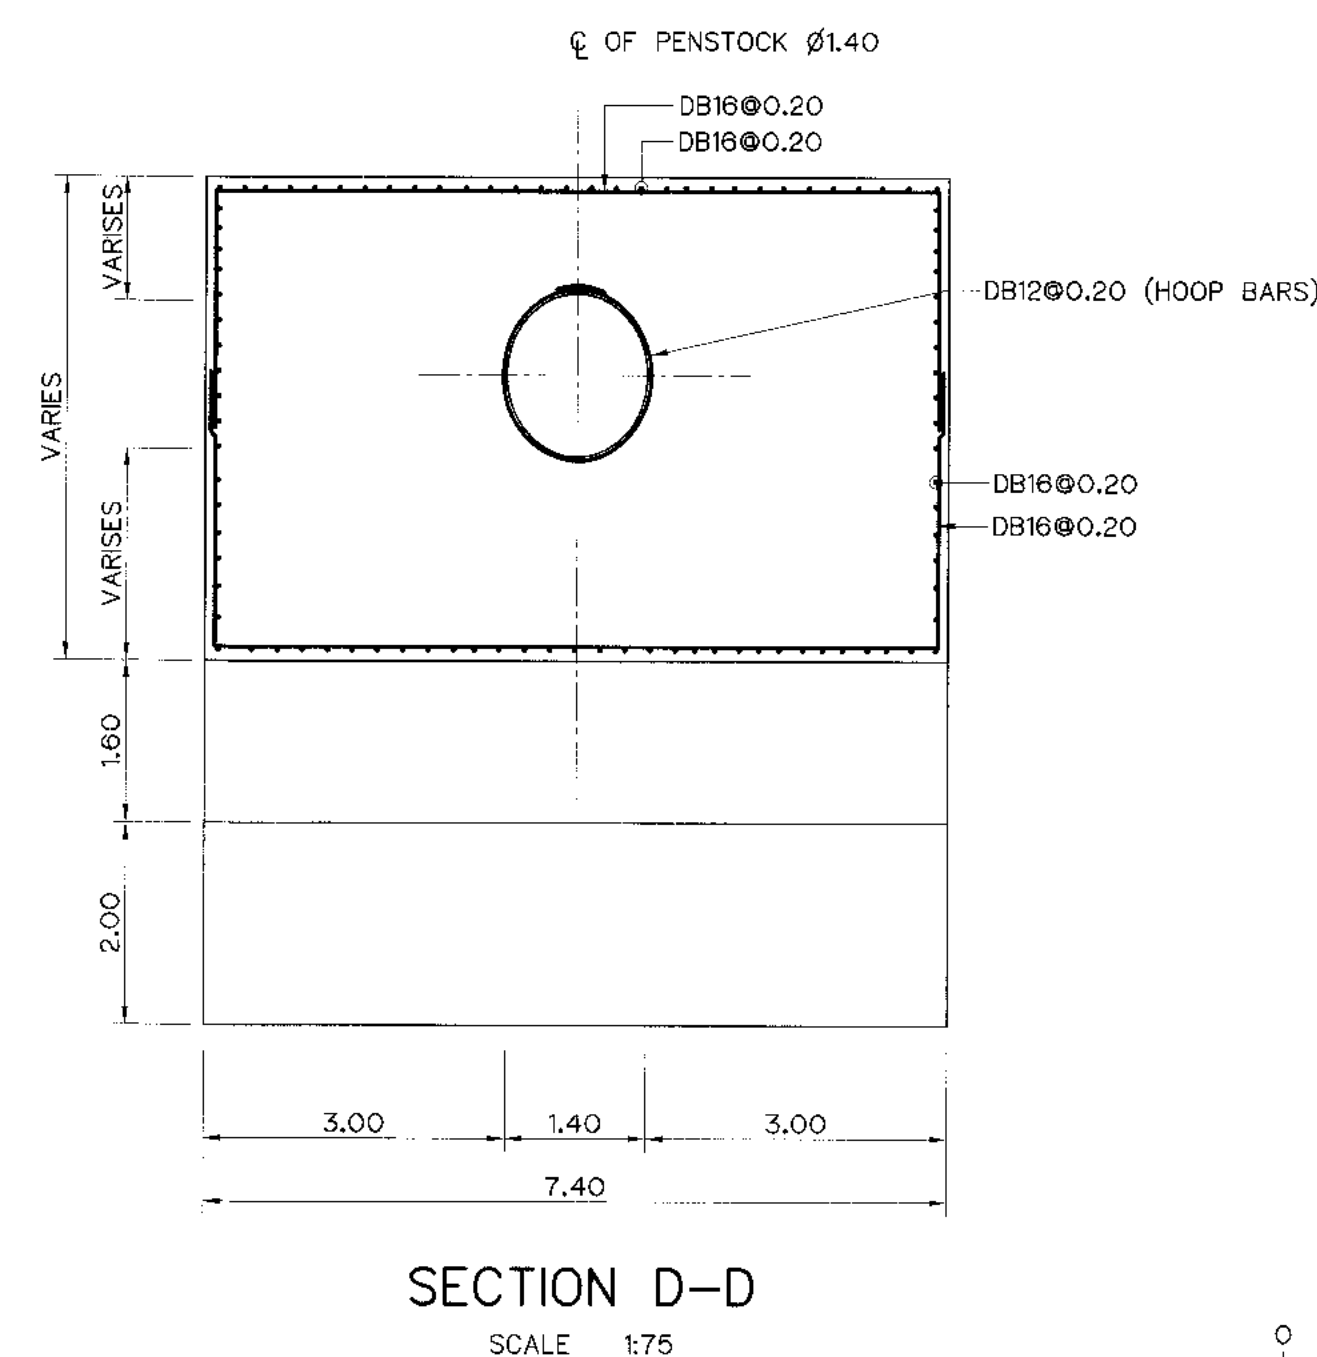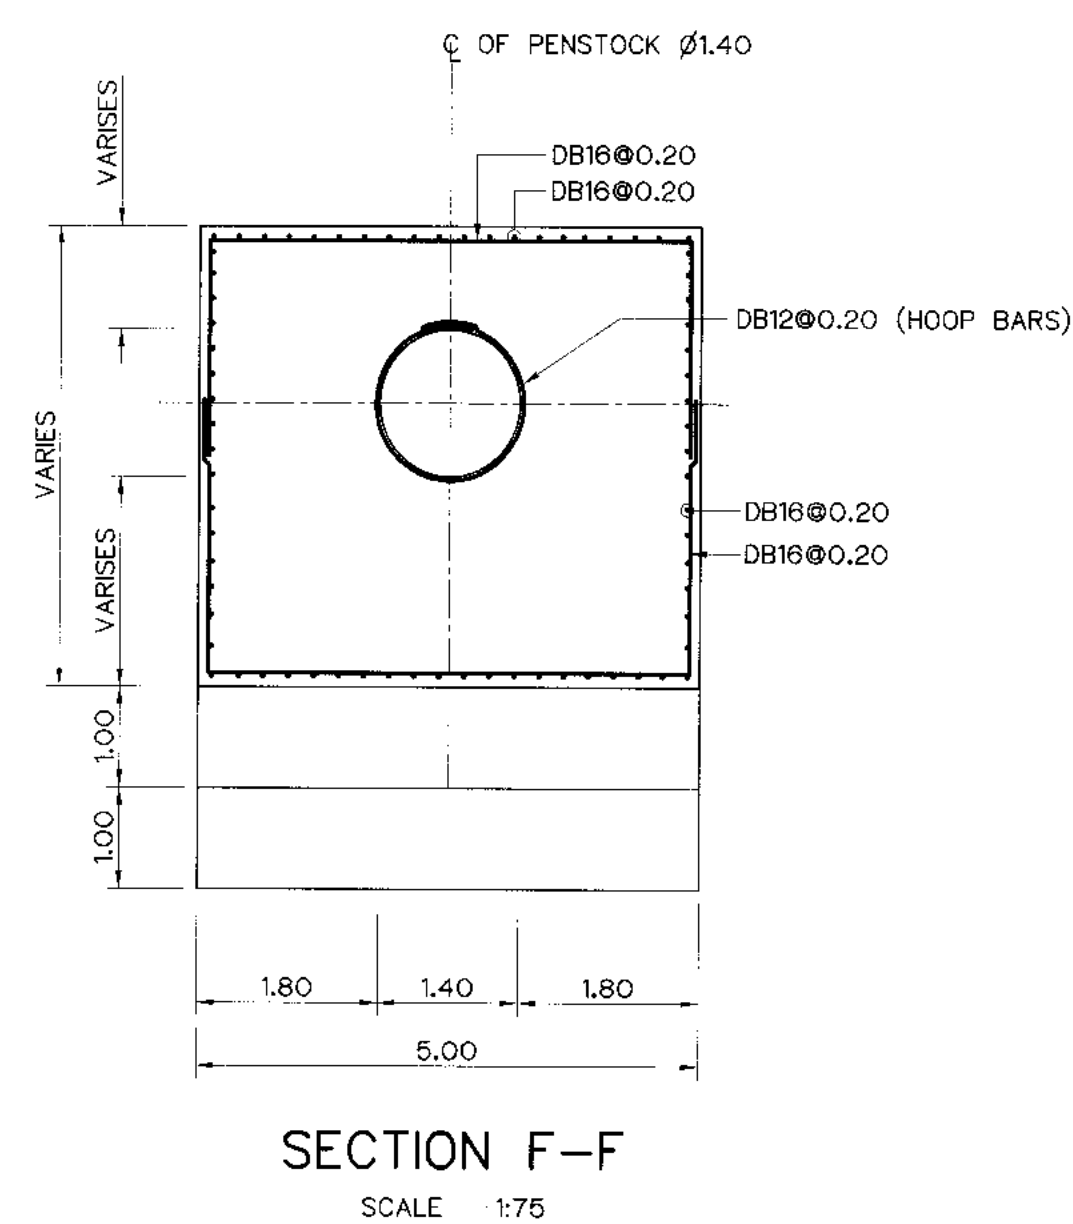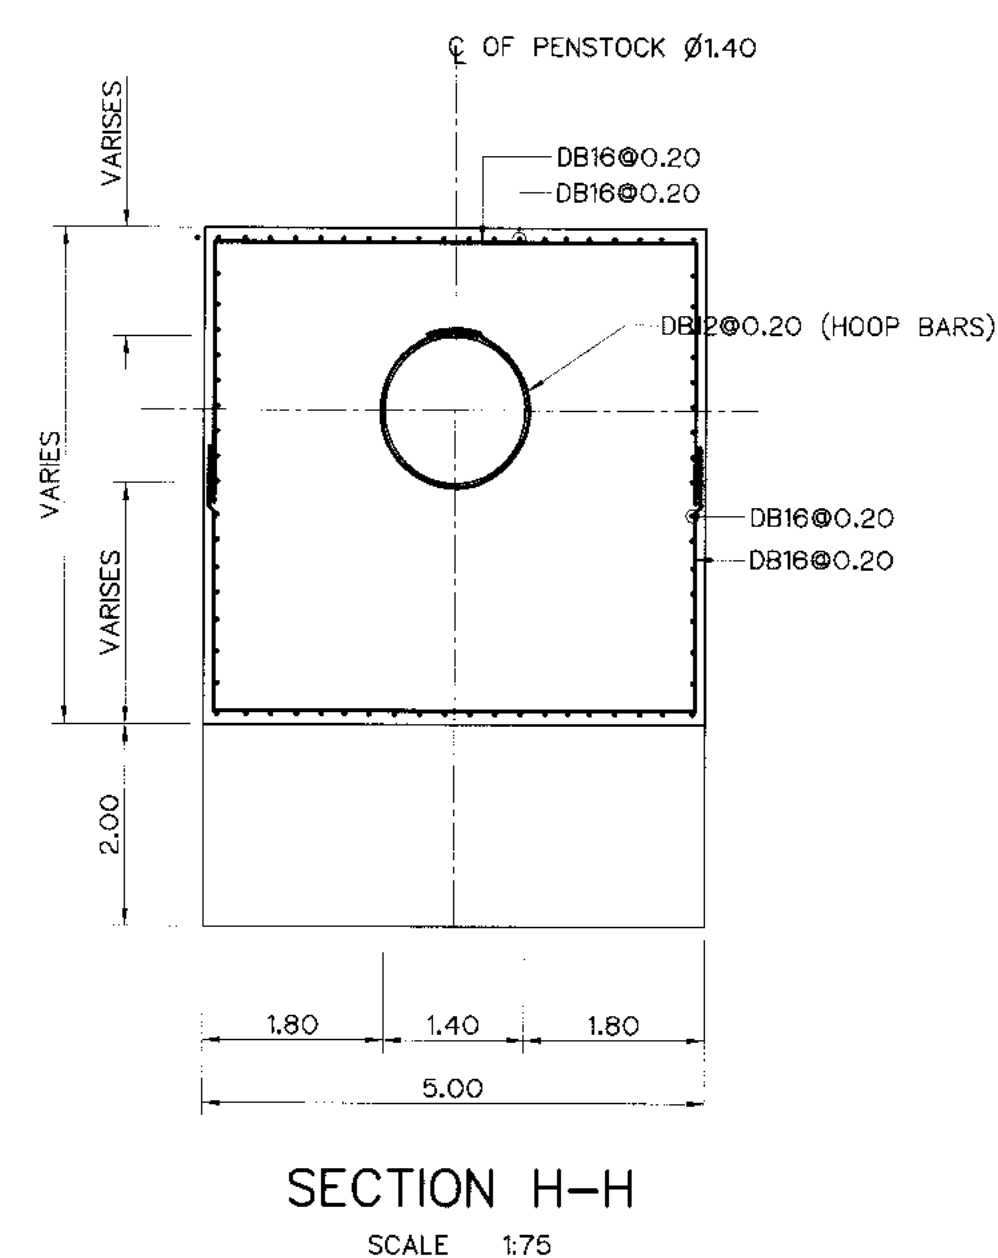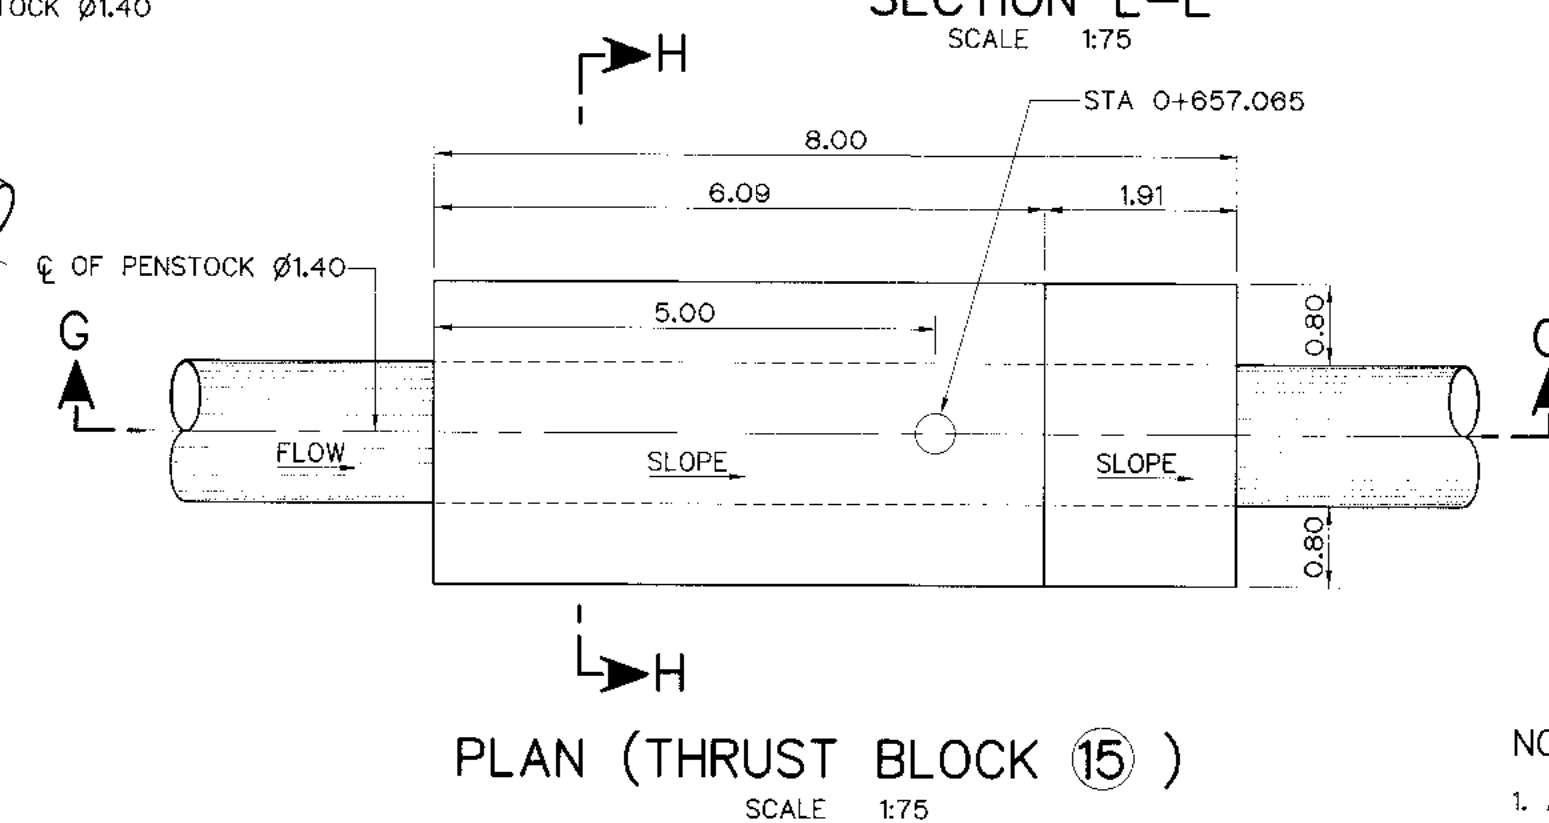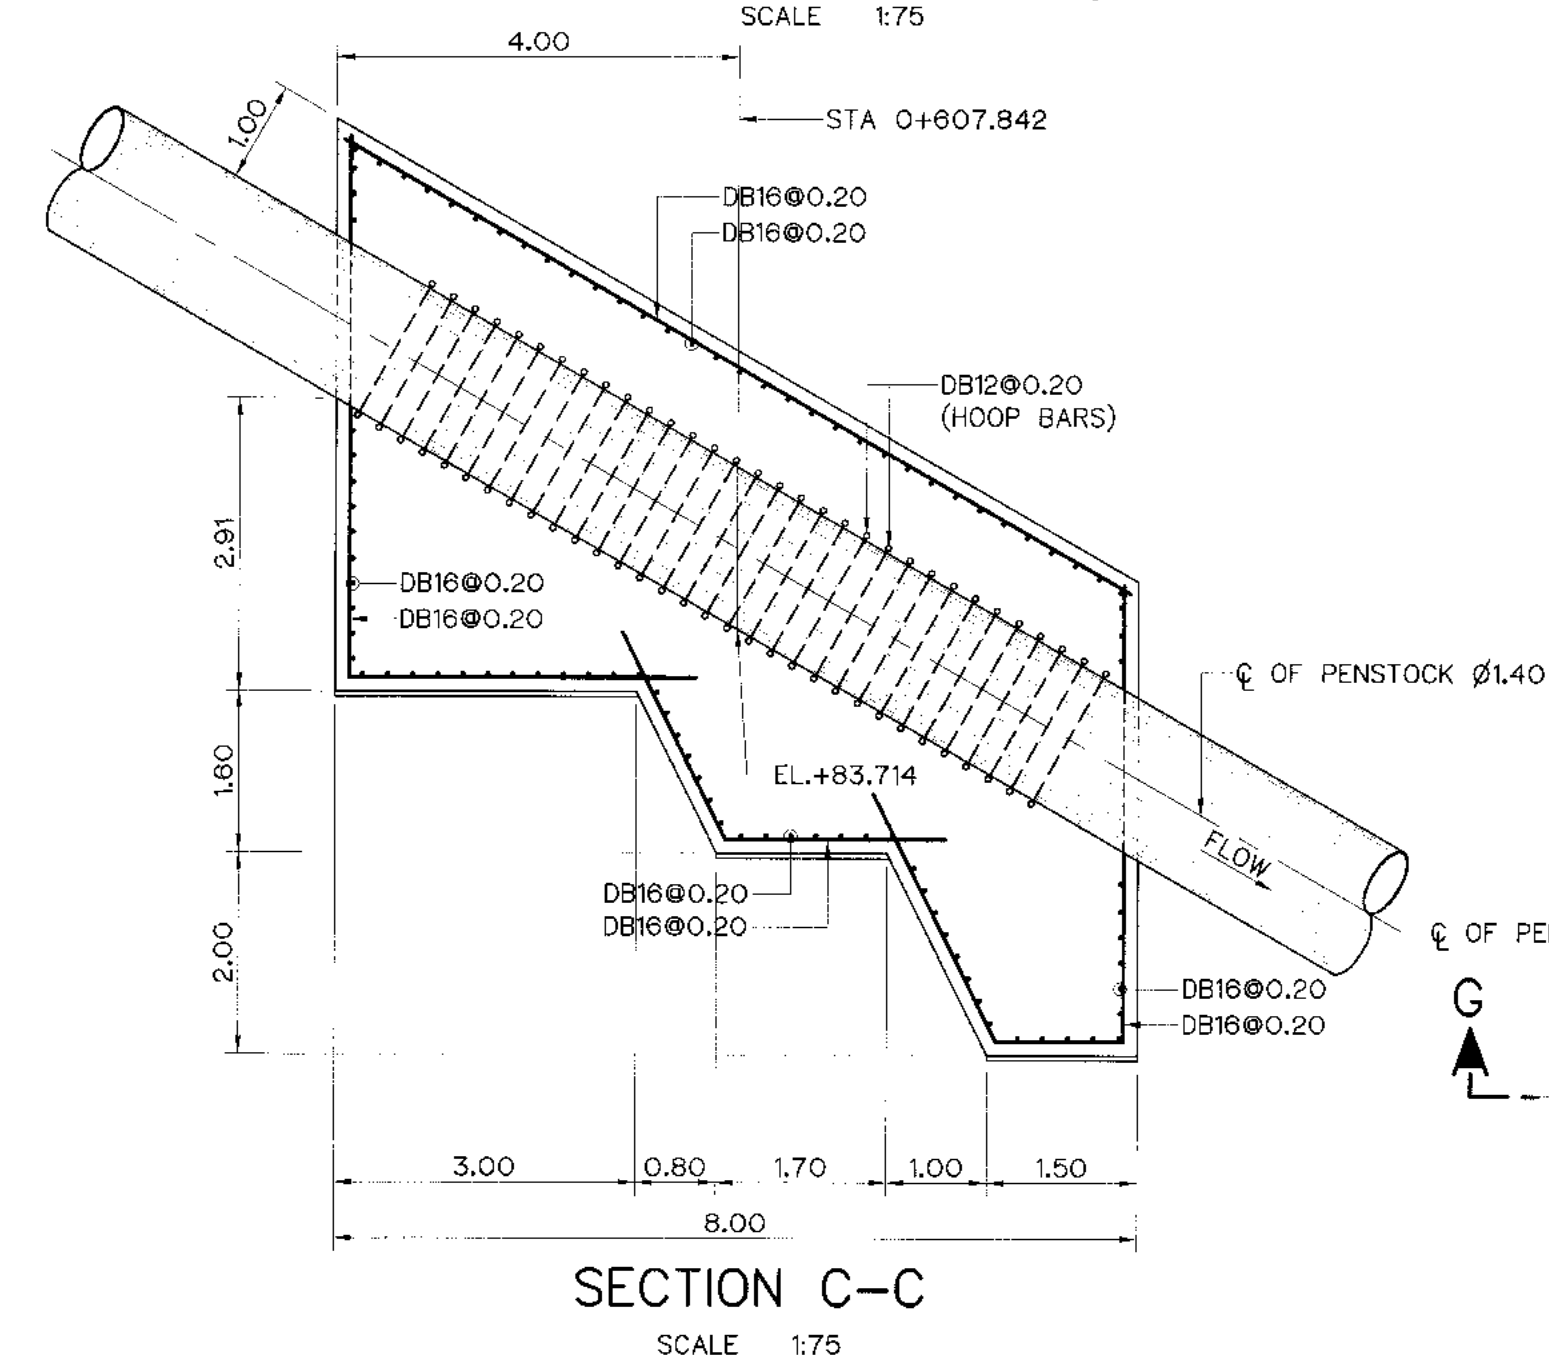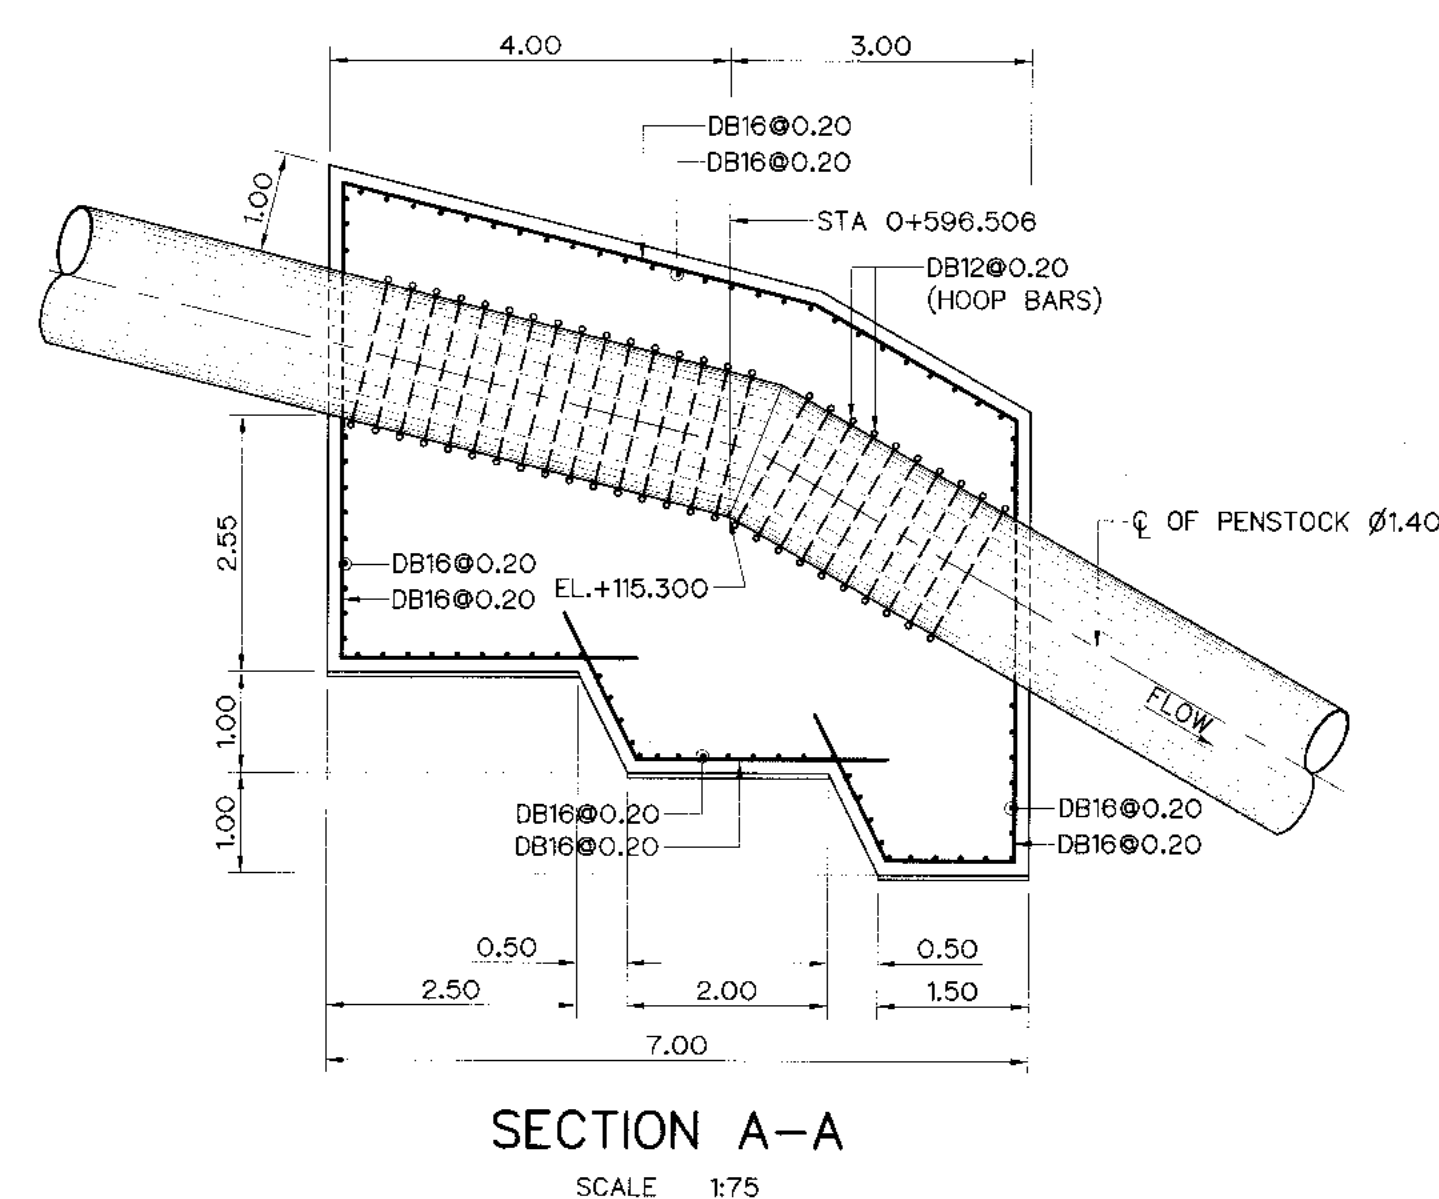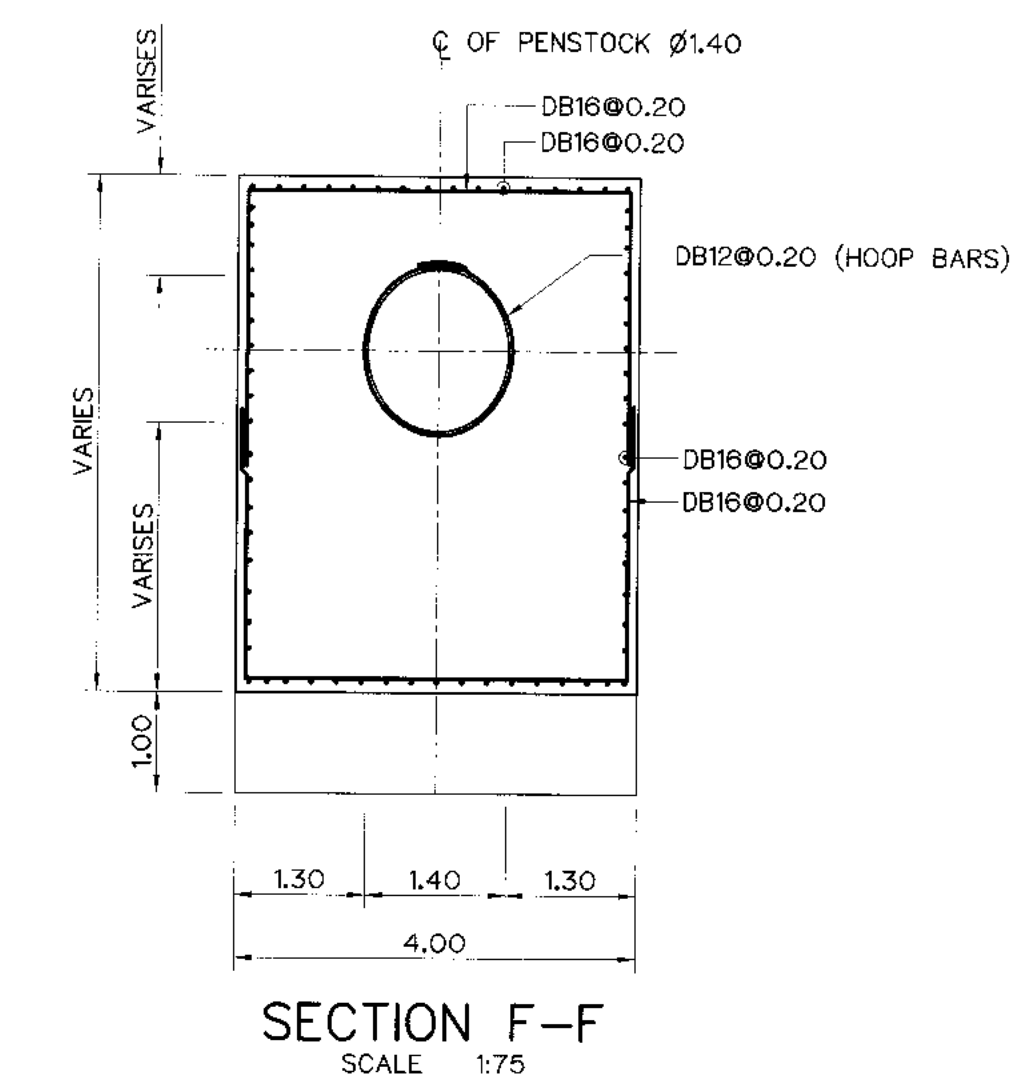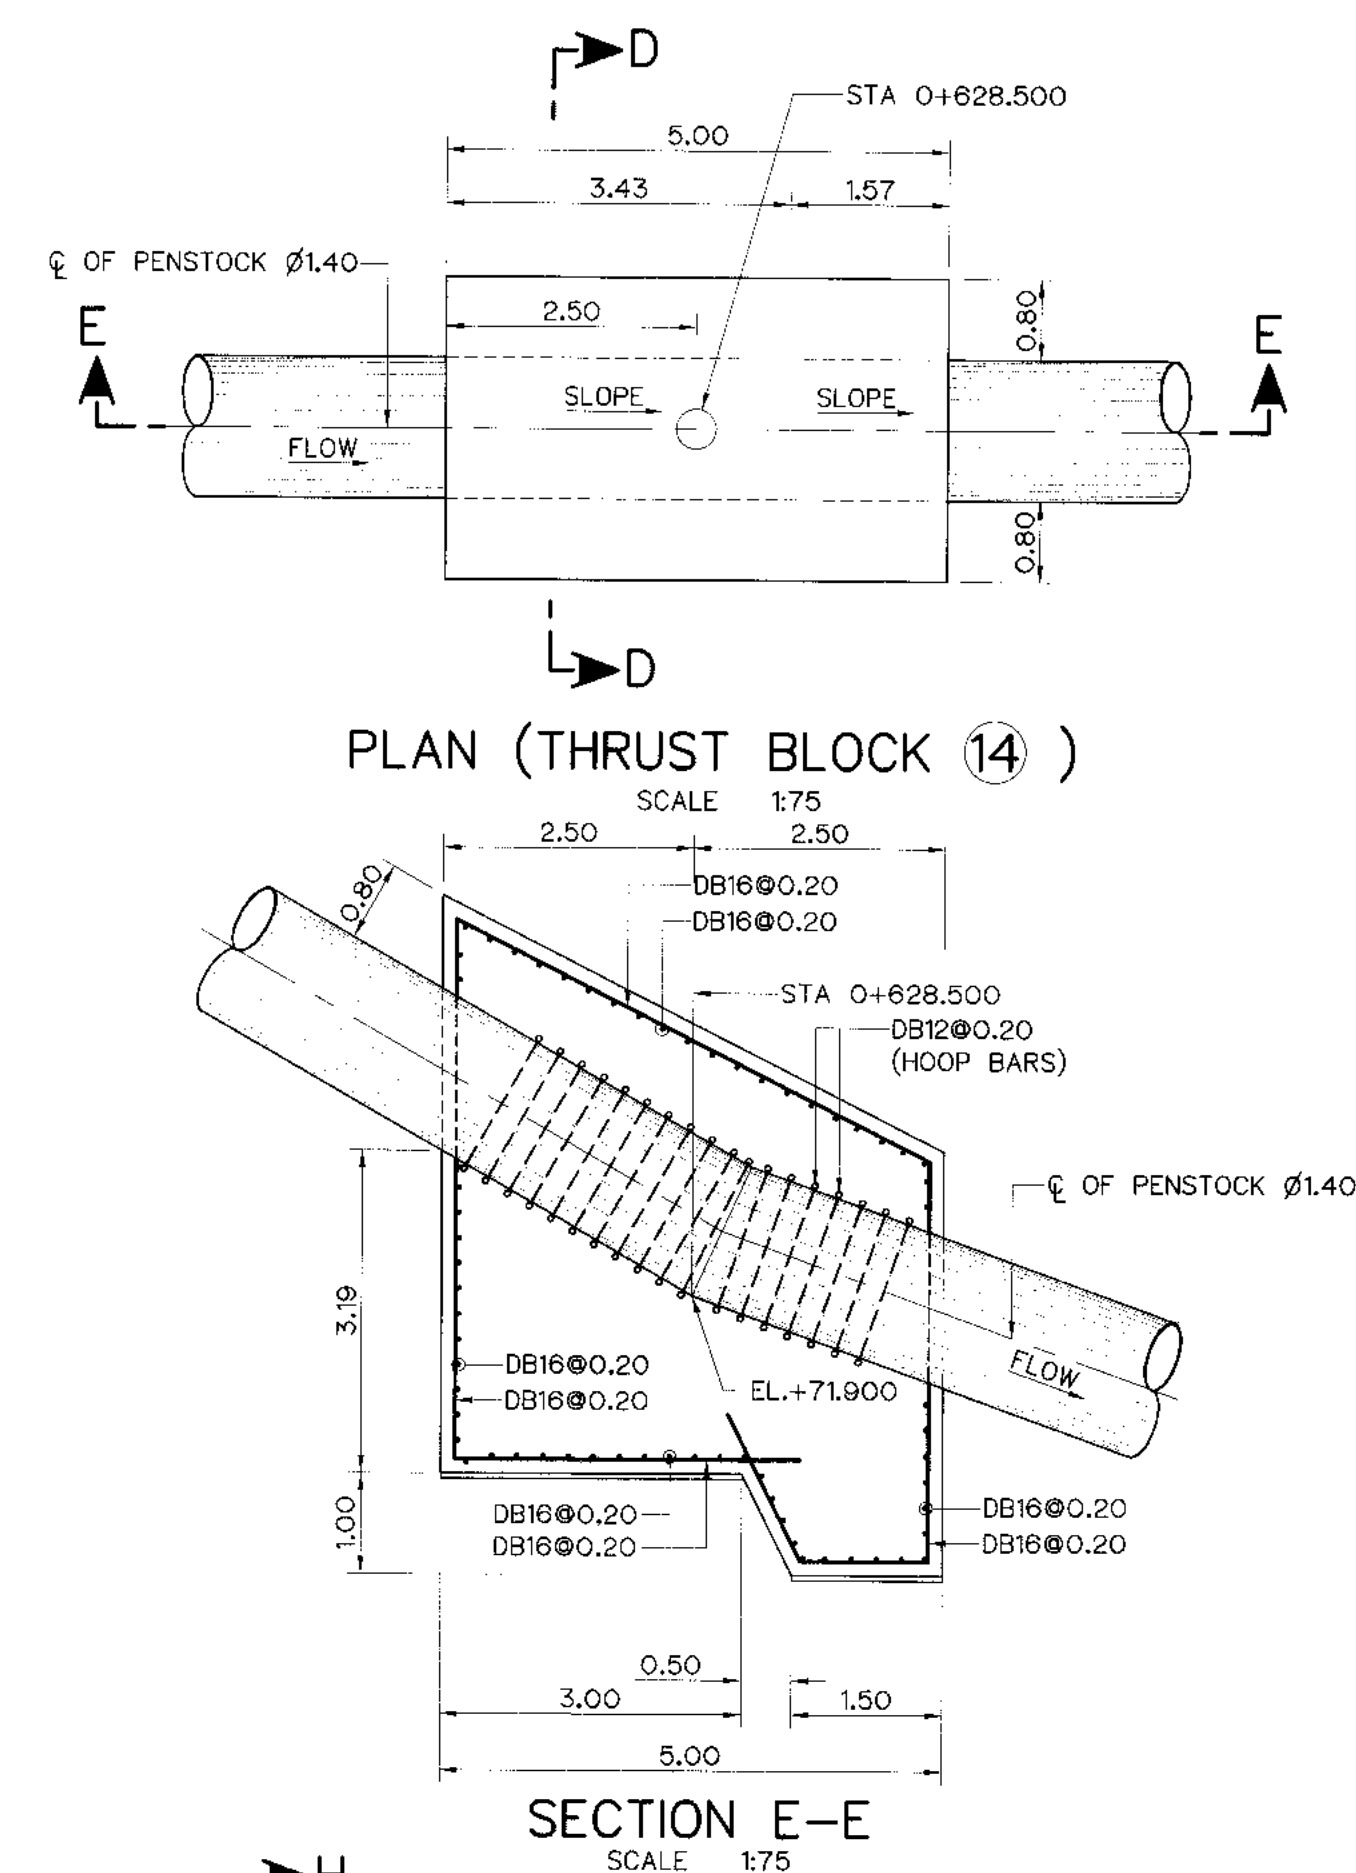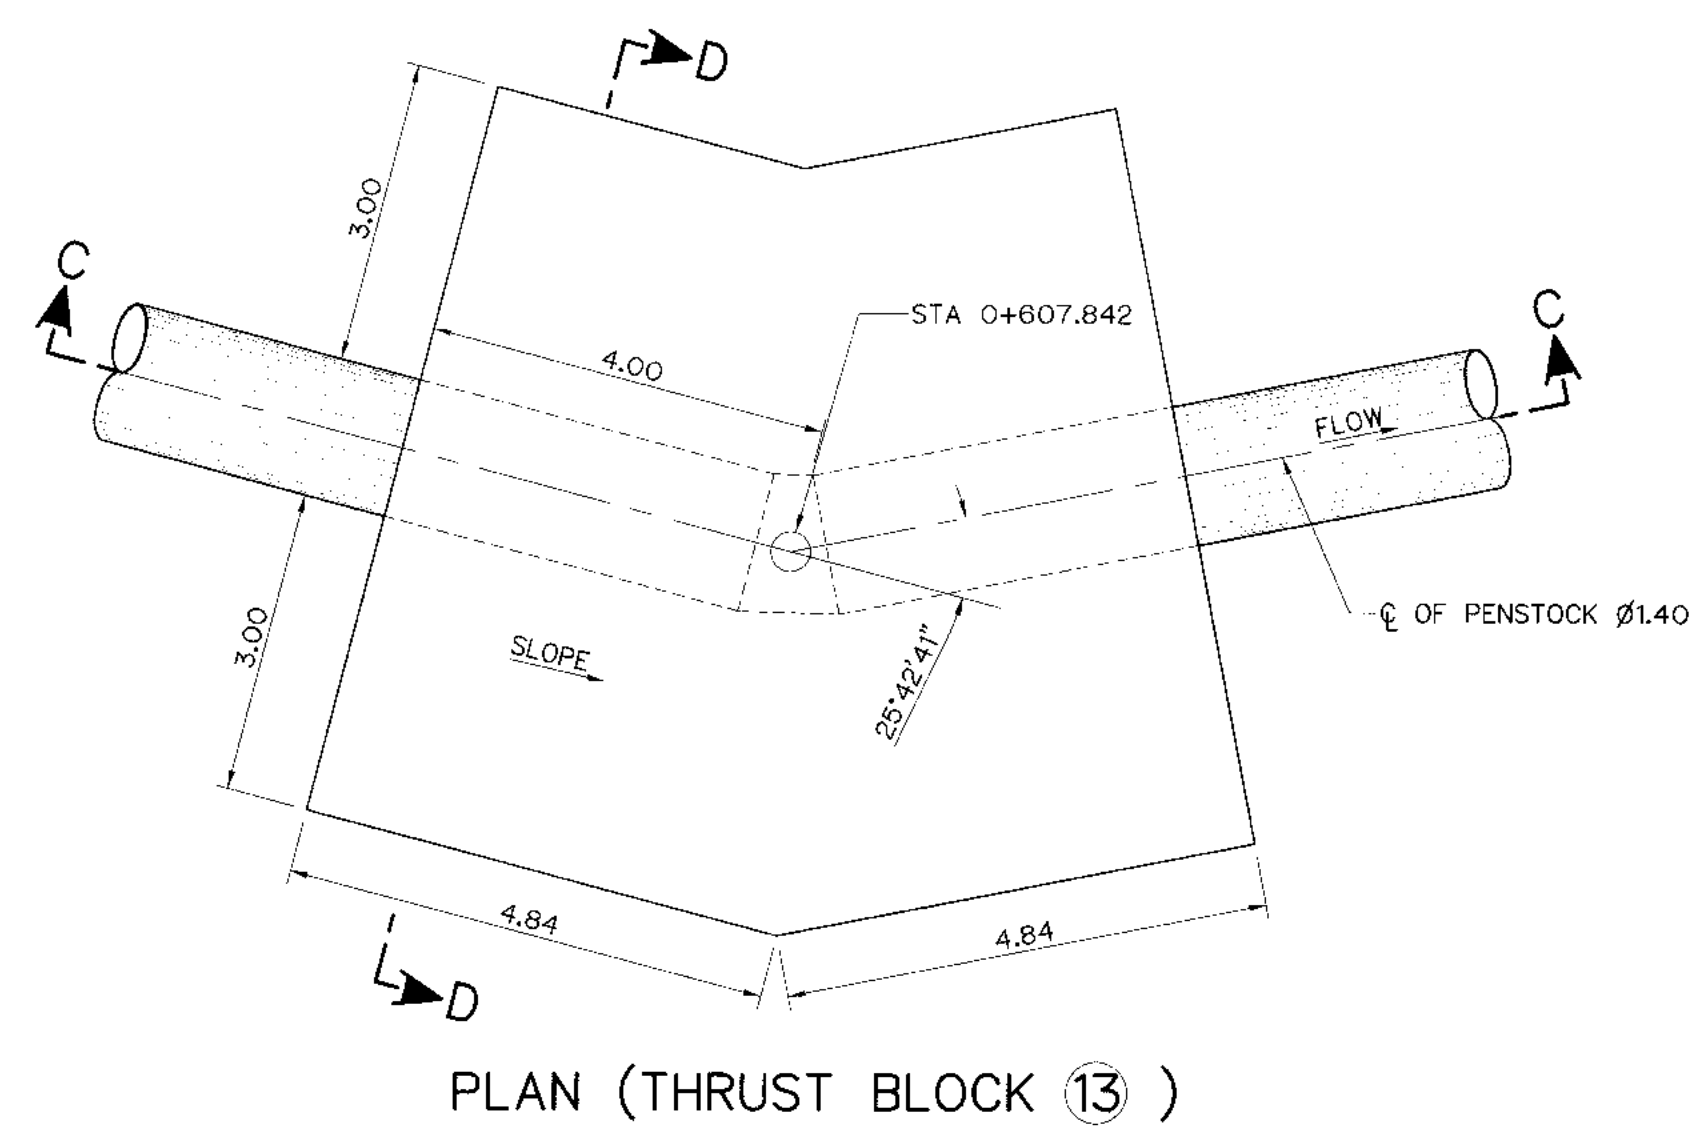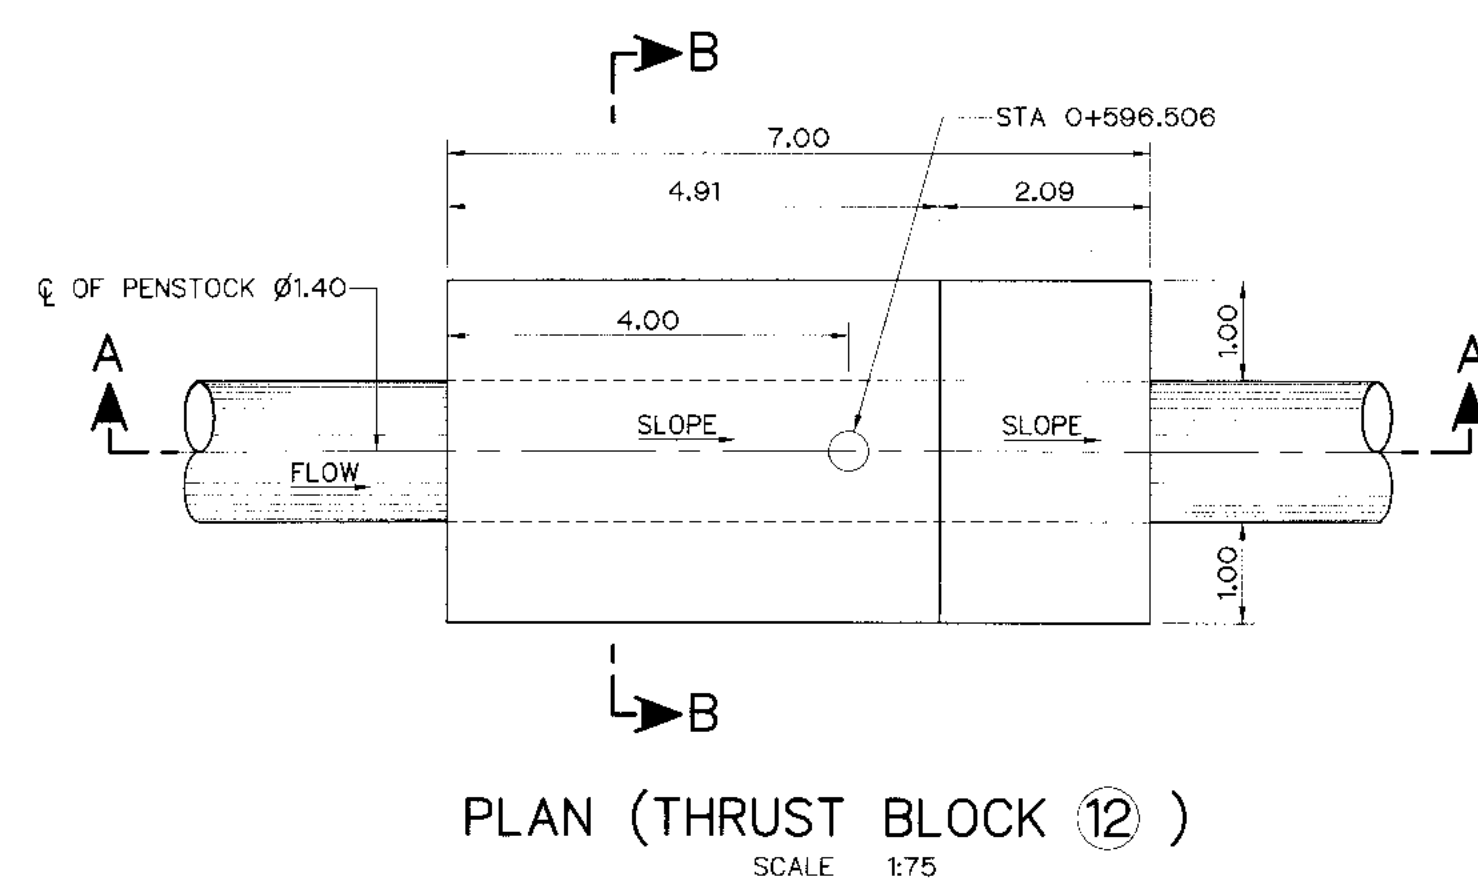


- NOTES :


1. ALL DIMENSIONS AND ELEVATIONS (M.S.L.) ARE IN METERS, UNLESS OTHERWISE SHOWN.
2. SYMBOLS, ABBREVIATIONS AND GENERAL NOTES SEE DWG. NO. KLP-GN-03
3. THE ALIGNMENT OF THE HEADRACE AND RELATED STRUCTURES SHALL BE CHECKED AND CORRECTED BY THE CONTRACTOR TO SUIT THE FIELD CONDITIONS AND SHALL BE SUBMITTED TO DEDE'S FIELD ENGINEER FOR APPROVAL

REFERENCE DRAWINGS :


1. PENSTOCK PLAN AND PROFILE, STA. 0+500 TO STA. 0+693.571 KLP-PS-01 TO 02

 KINGDOM OF THAILAND Department of Alternative Energy Development and Efficiency MINISTRY OF ENERGY	
KLONG LAM PLOK HYDROPOWER PROJECT	
CIVIL WORKS AND TRANSMISSION LINE PENSTOCK	
THRUST BLOCK PLAN ,SECTIONS REINFORCEMENT DETAILS 4/	
 P&C MANAGEMENT CO.,LTD.	 Department of Alternative Energy Development and Efficiency MINISTRY OF ENERGY
DESIGNED <i>[Signature]</i> 28.290.74 28.28.226	REVIEWED <i>[Signature]</i>
DRAWN <i>[Signature]</i>	SUBMITTED <i>[Signature]</i>
CHECKED <i>[Signature]</i> 28.28.226	RECOMMENDED <i>[Signature]</i>
PROJECT MANAGER <i>[Signature]</i> 09/03/2559	APPROVED <i>[Signature]</i>
DRAWING NO. KLP-PS-06	SHEET NO. 64 OF 110

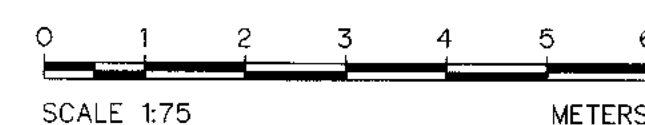


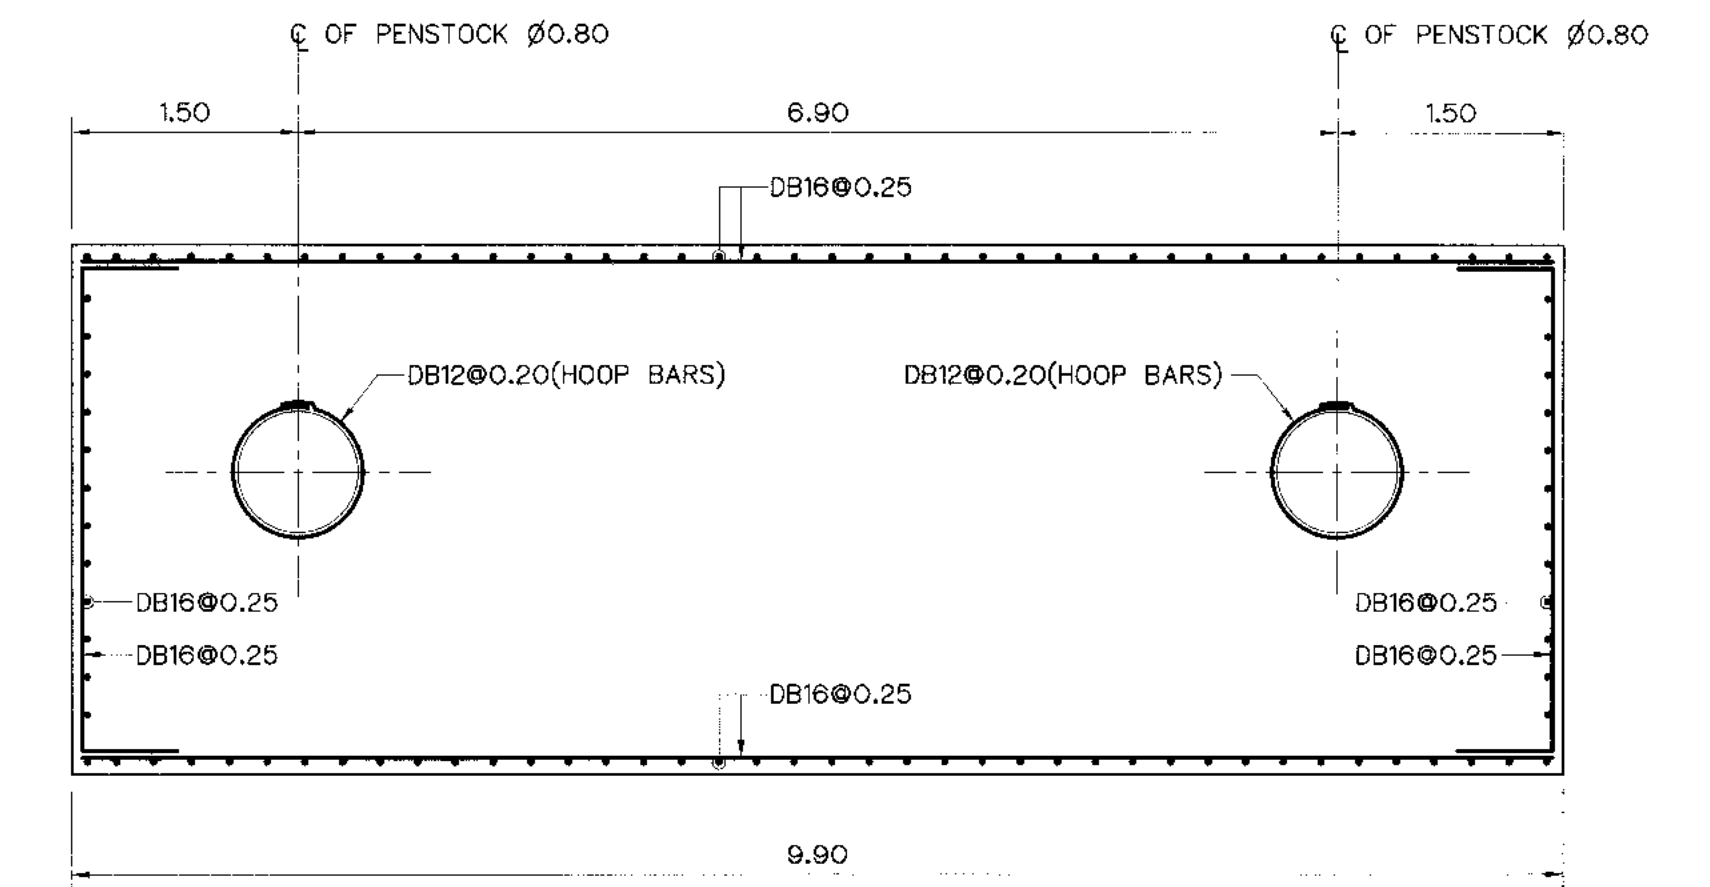


SECTION B-B
SCALE 1:50

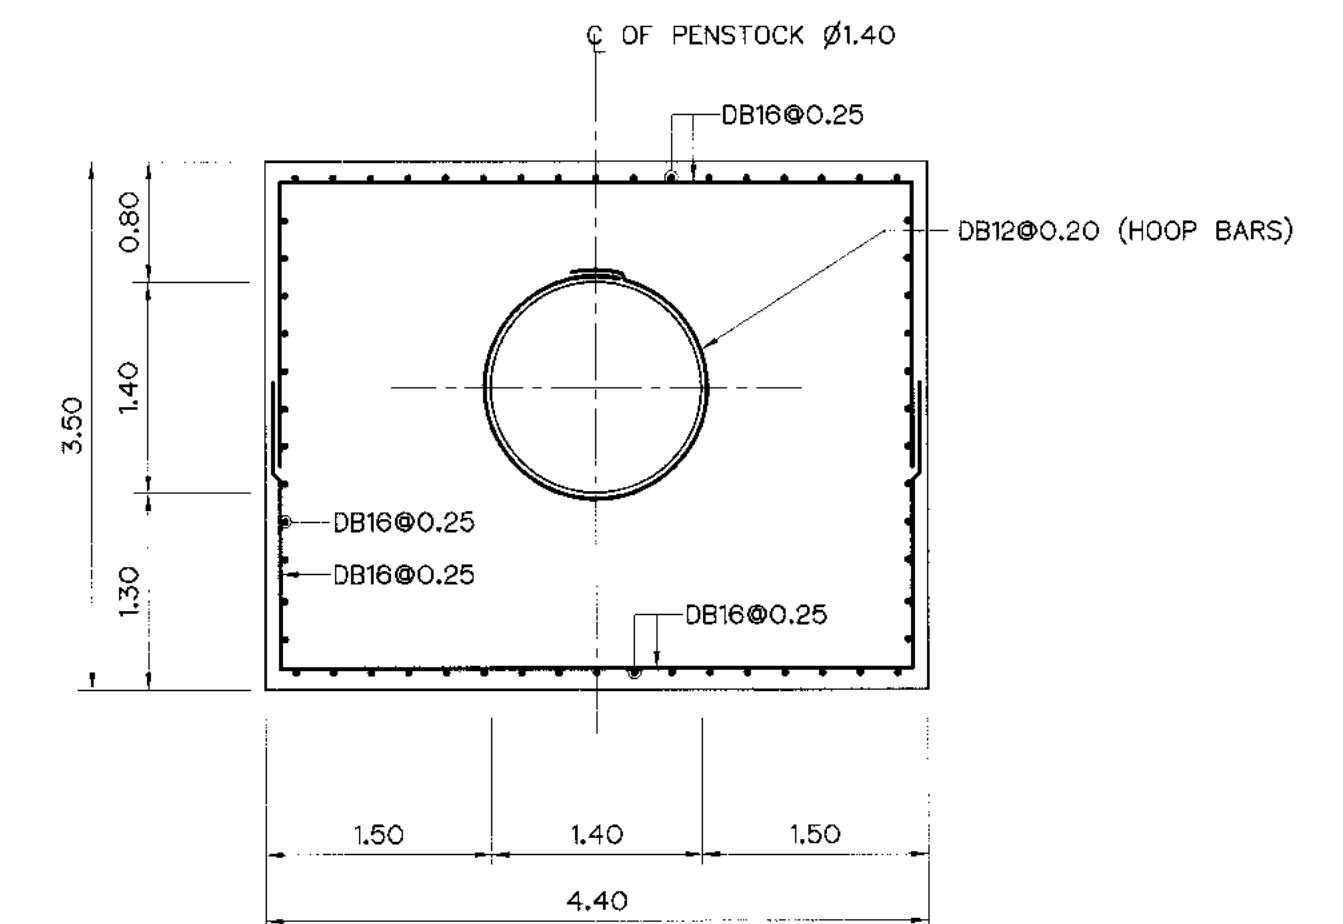


SECTION C-C
SCALE 1:50

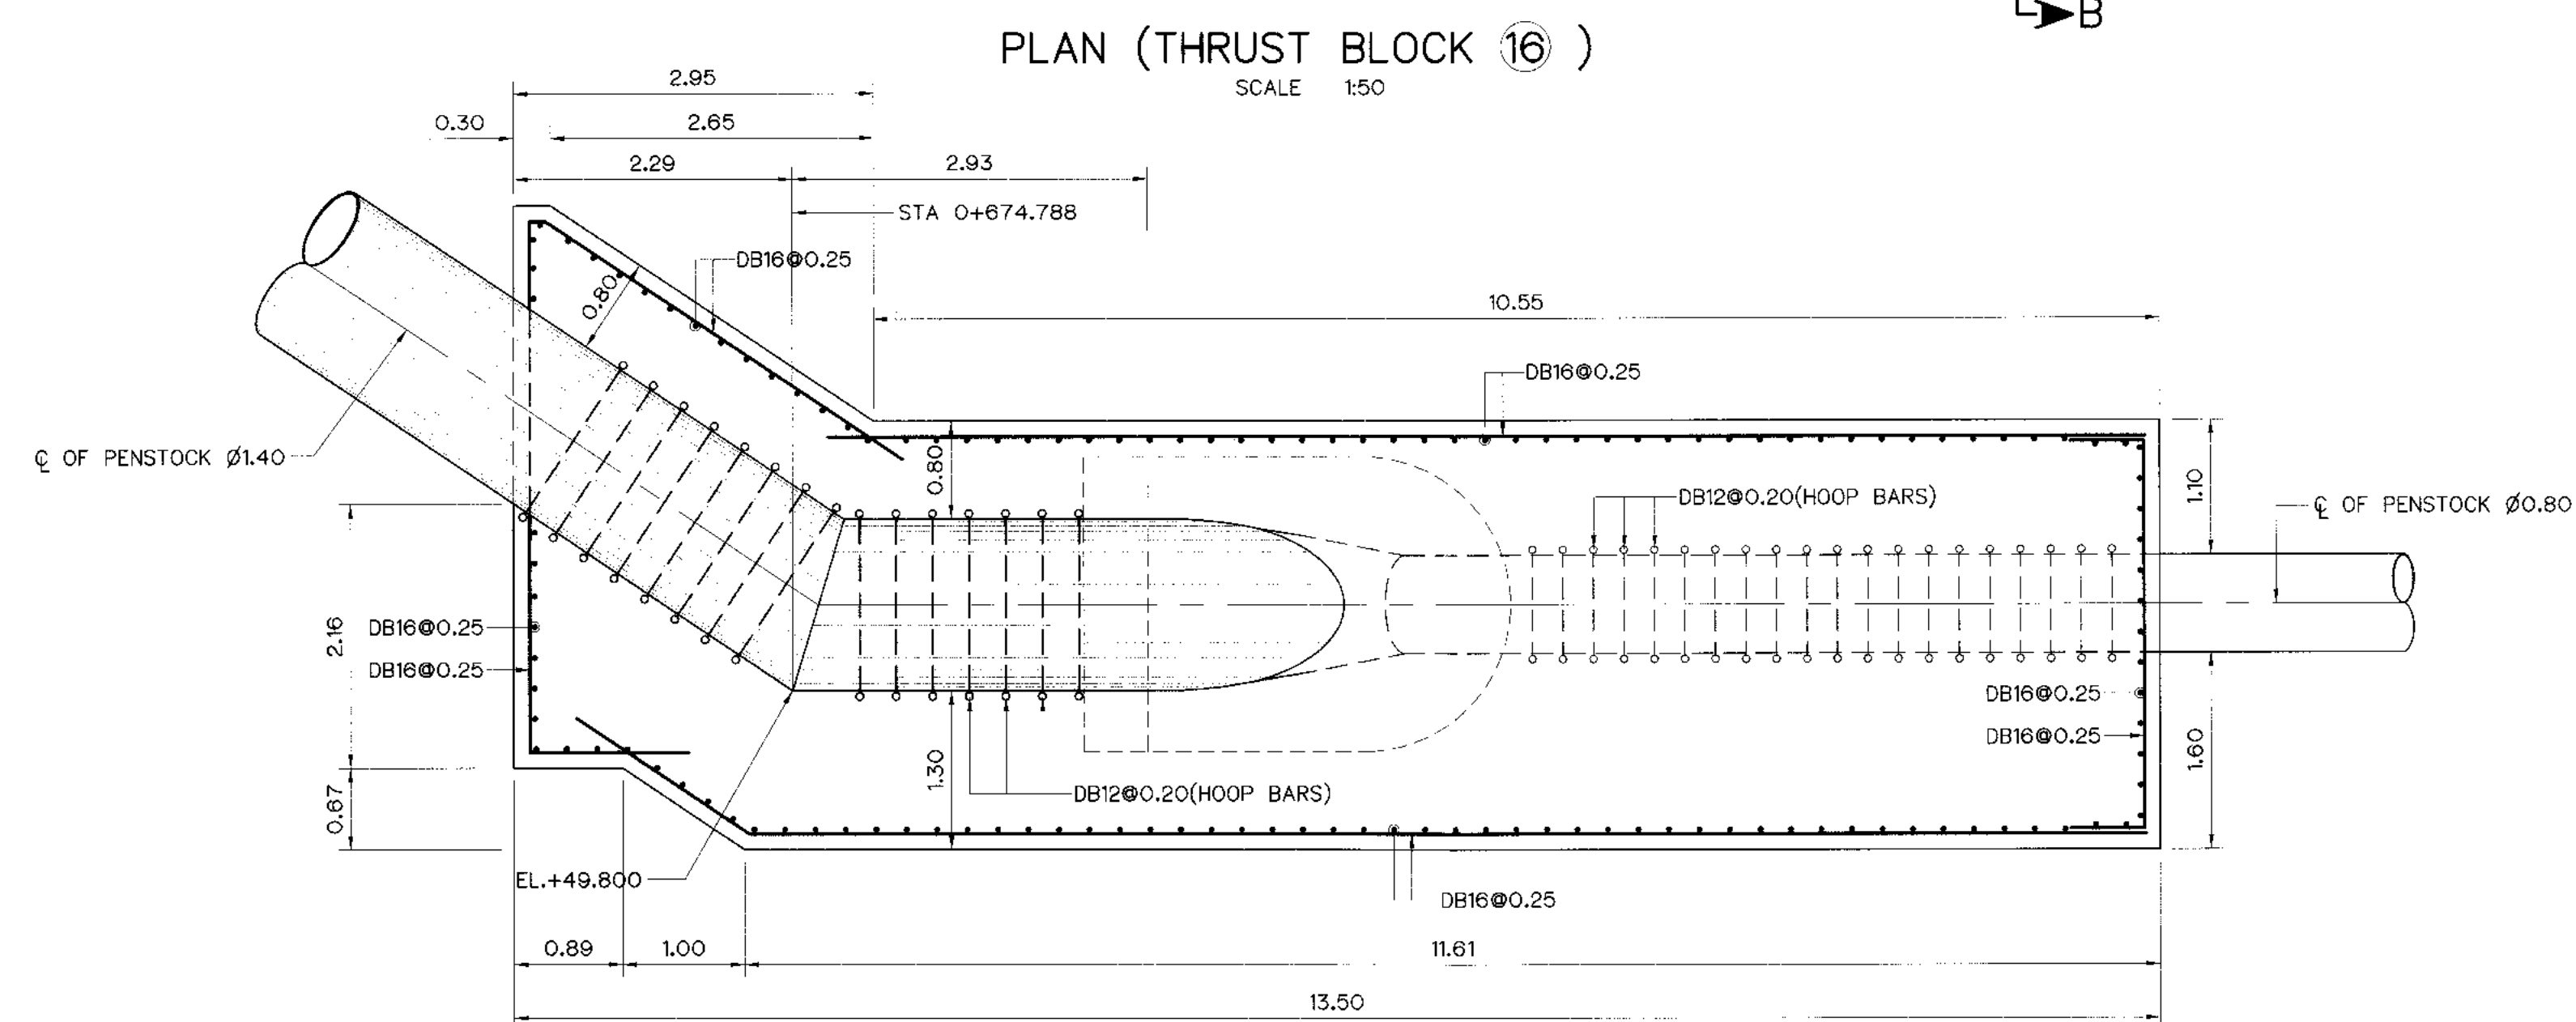

SECTION A-A
SCALE 1:50

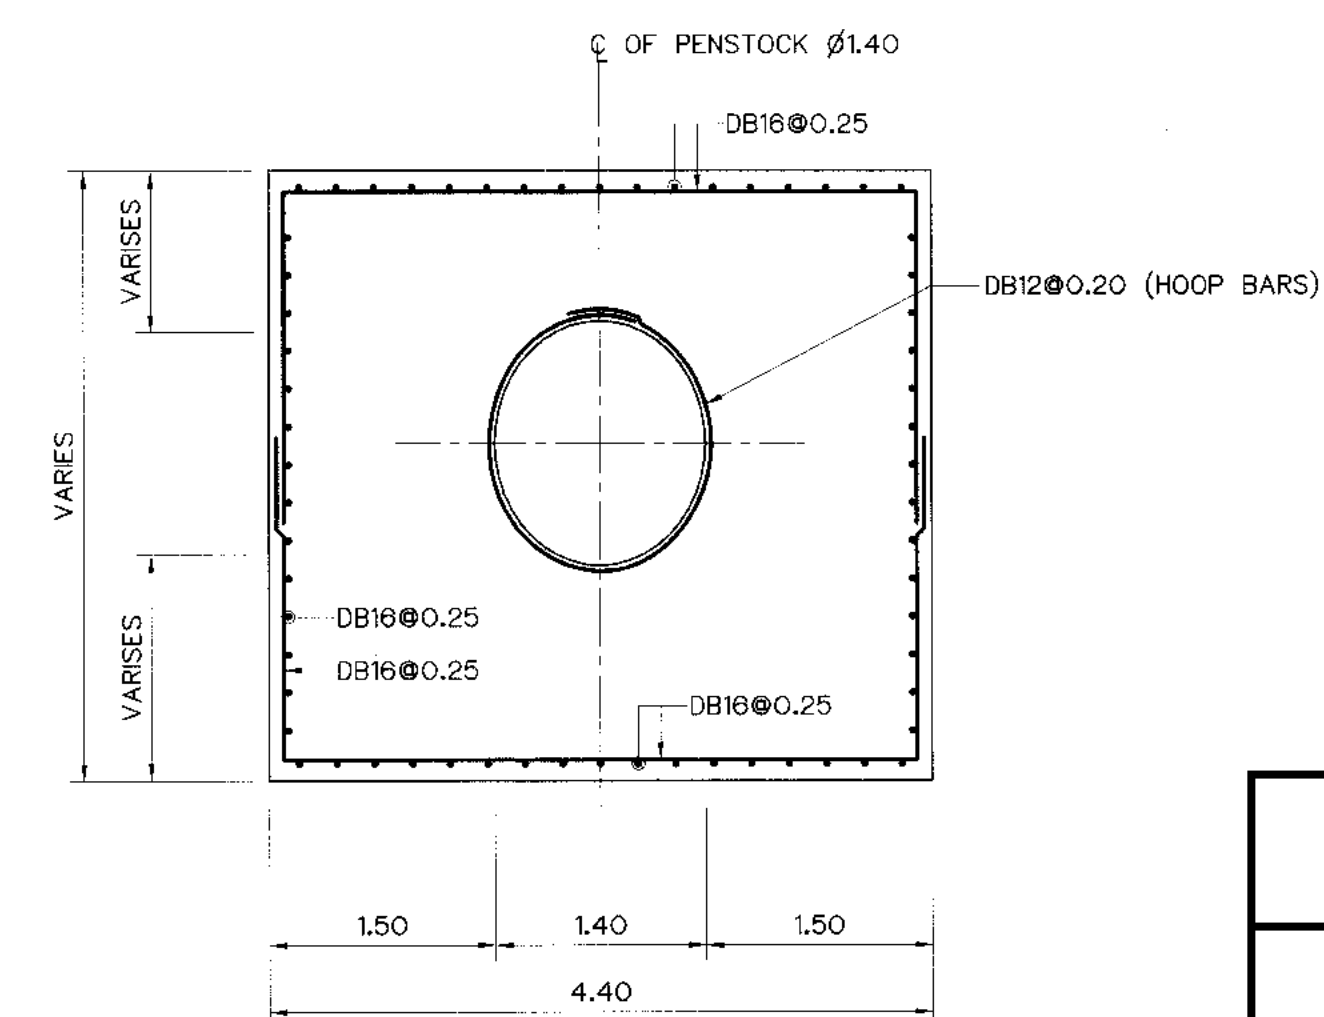


SECTION D-D
SCALE 1:50

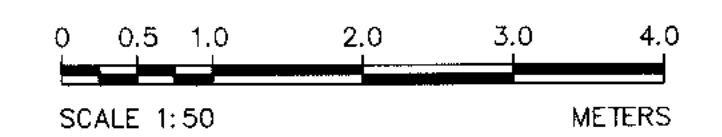


1. PENSTOCK PLAN AND PROFILE, STA. 0+500 TO STA. 0+693.571 KLP-PS-01 TO 02

3				
2				
1				
NO.	DATE	REVISIONS	CHECKED	APPROVE
	CONSULTANTS		DEDE	

 KINGDOM OF THAILAND Department of Alternative Energy Development and Efficiency MINISTRY OF ENERGY	
KLONG LAM PLOK HYDROPOWER PROJECT	
CIVIL WORKS AND TRANSMISSION LINE PENSTOCK	
THRUST BLOCK PLAN ,SECTIONS REINFORCEMENT DETAILS 5/5	
 P&C MANAGEMENT CO.,LTD.	 Department of Alternative Energy Development and Efficiency MINISTRY OF ENERGY
DESIGNED <i>[Signature]</i> <i>05</i> 01.26074 <i>05</i> 01.0226	REVIEWED <i>[Signature]</i>
DRAWN <i>[Signature]</i>	SUBMITTED <i>[Signature]</i>
CHECKED <i>[Signature]</i> 01.26074 01.0226	APPROVED <i>[Signature]</i>
<i>02</i> PROJECT MANAGER	DRAINING NO. KLP-PS-07
DATE	SHEET NO. 65 OF 110

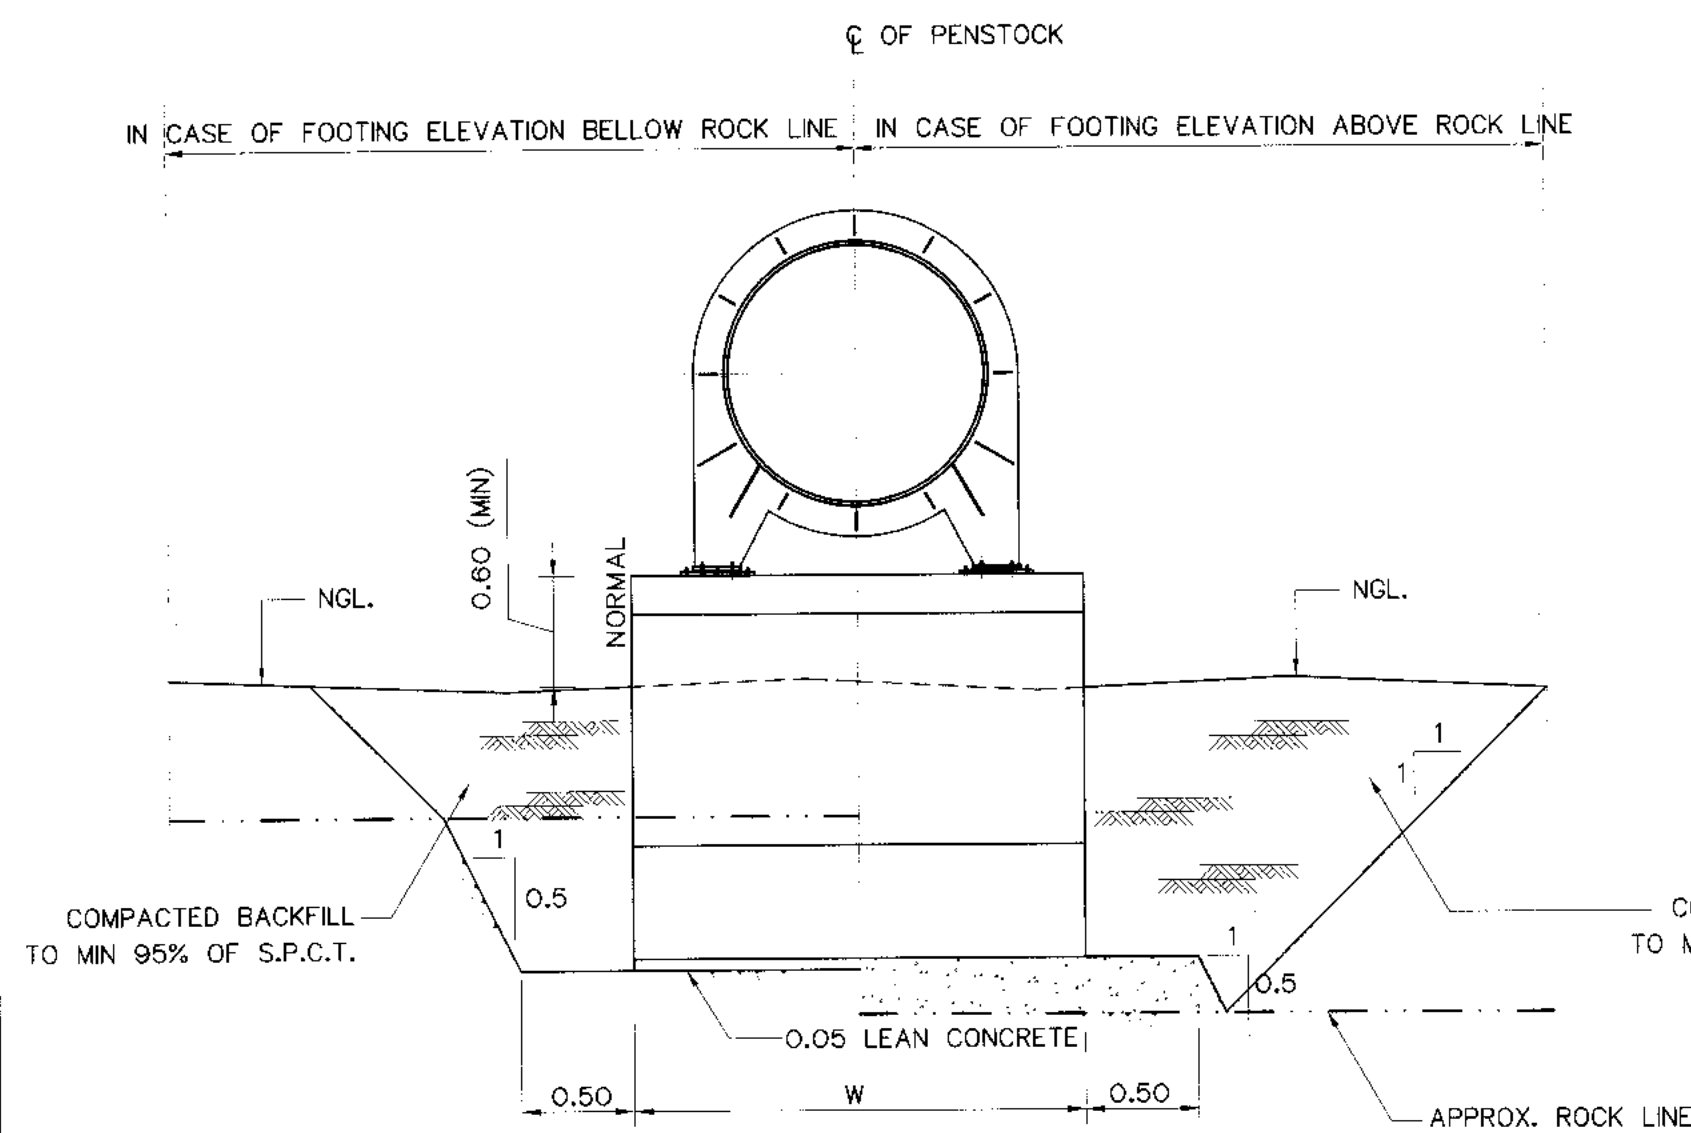


N.G.L. BELOW INVERT ELEVATION

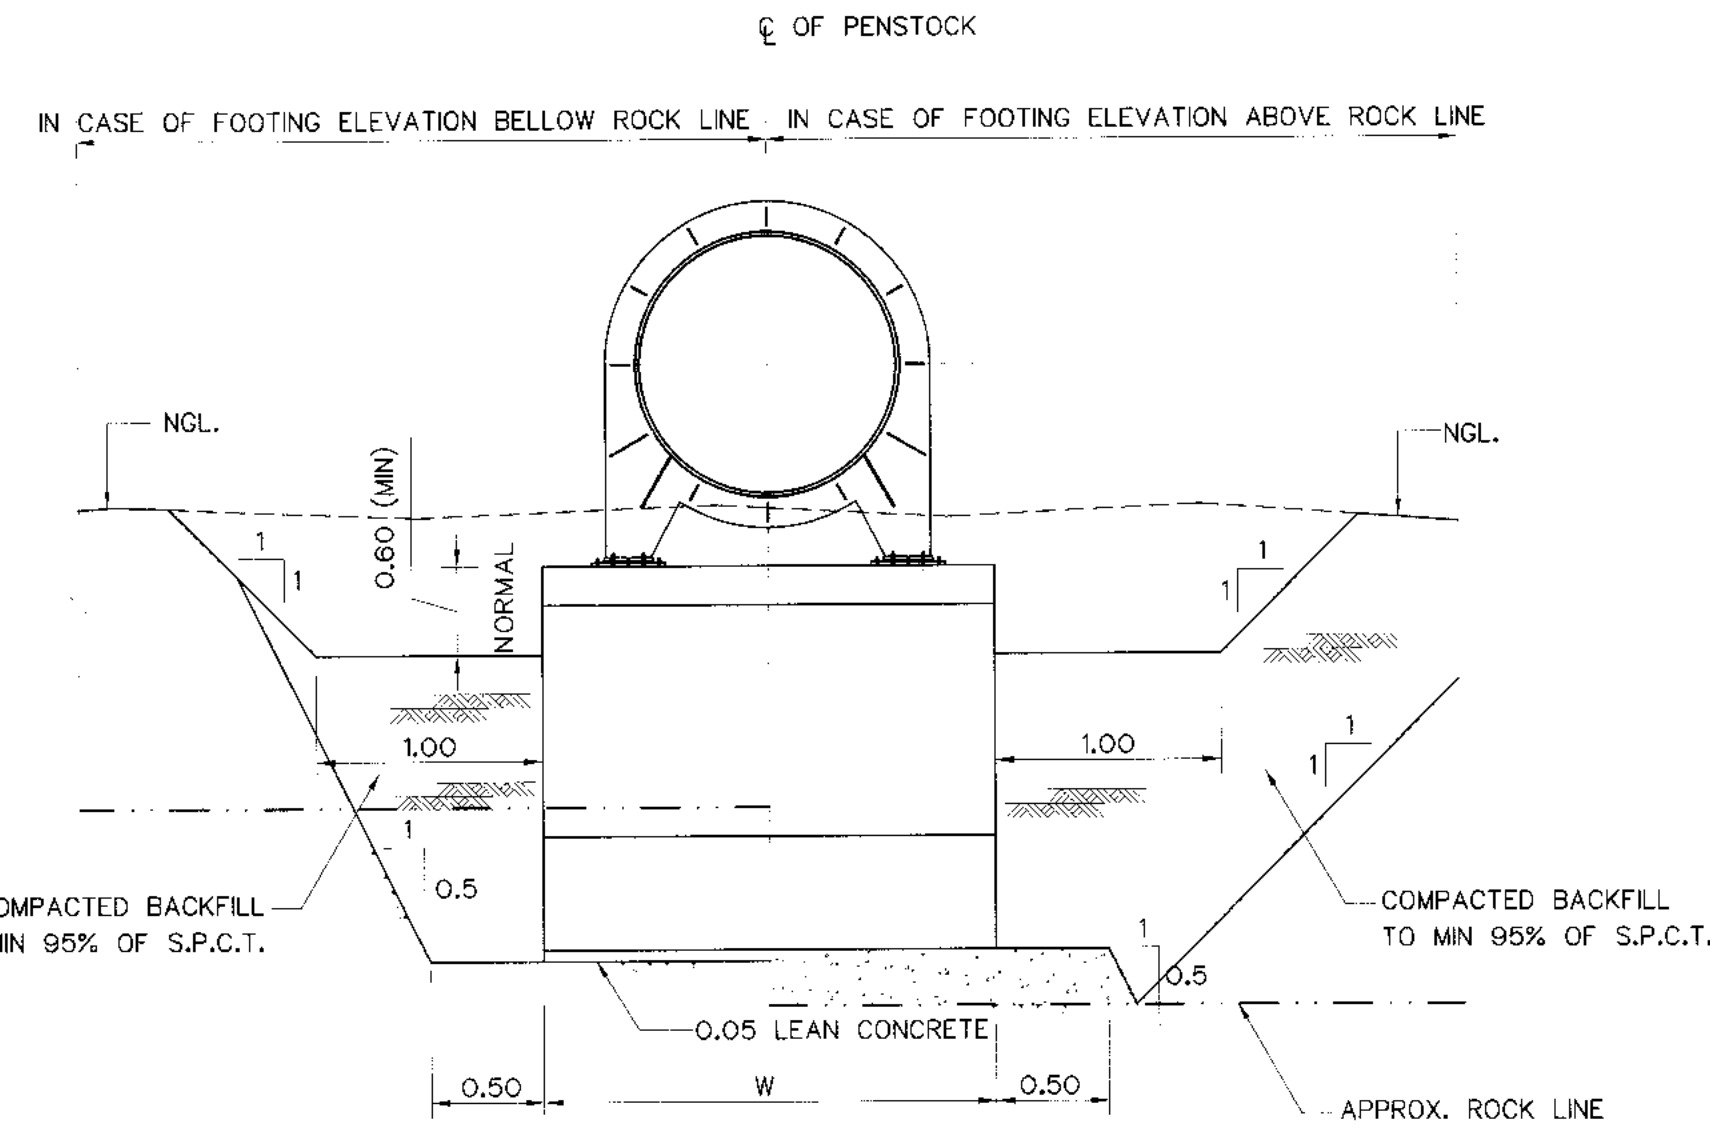


N.G.L. ABOVE INVERT ELEVATION


TYPICAL SECTION OF PENSTOCK
NOT TO SCALE

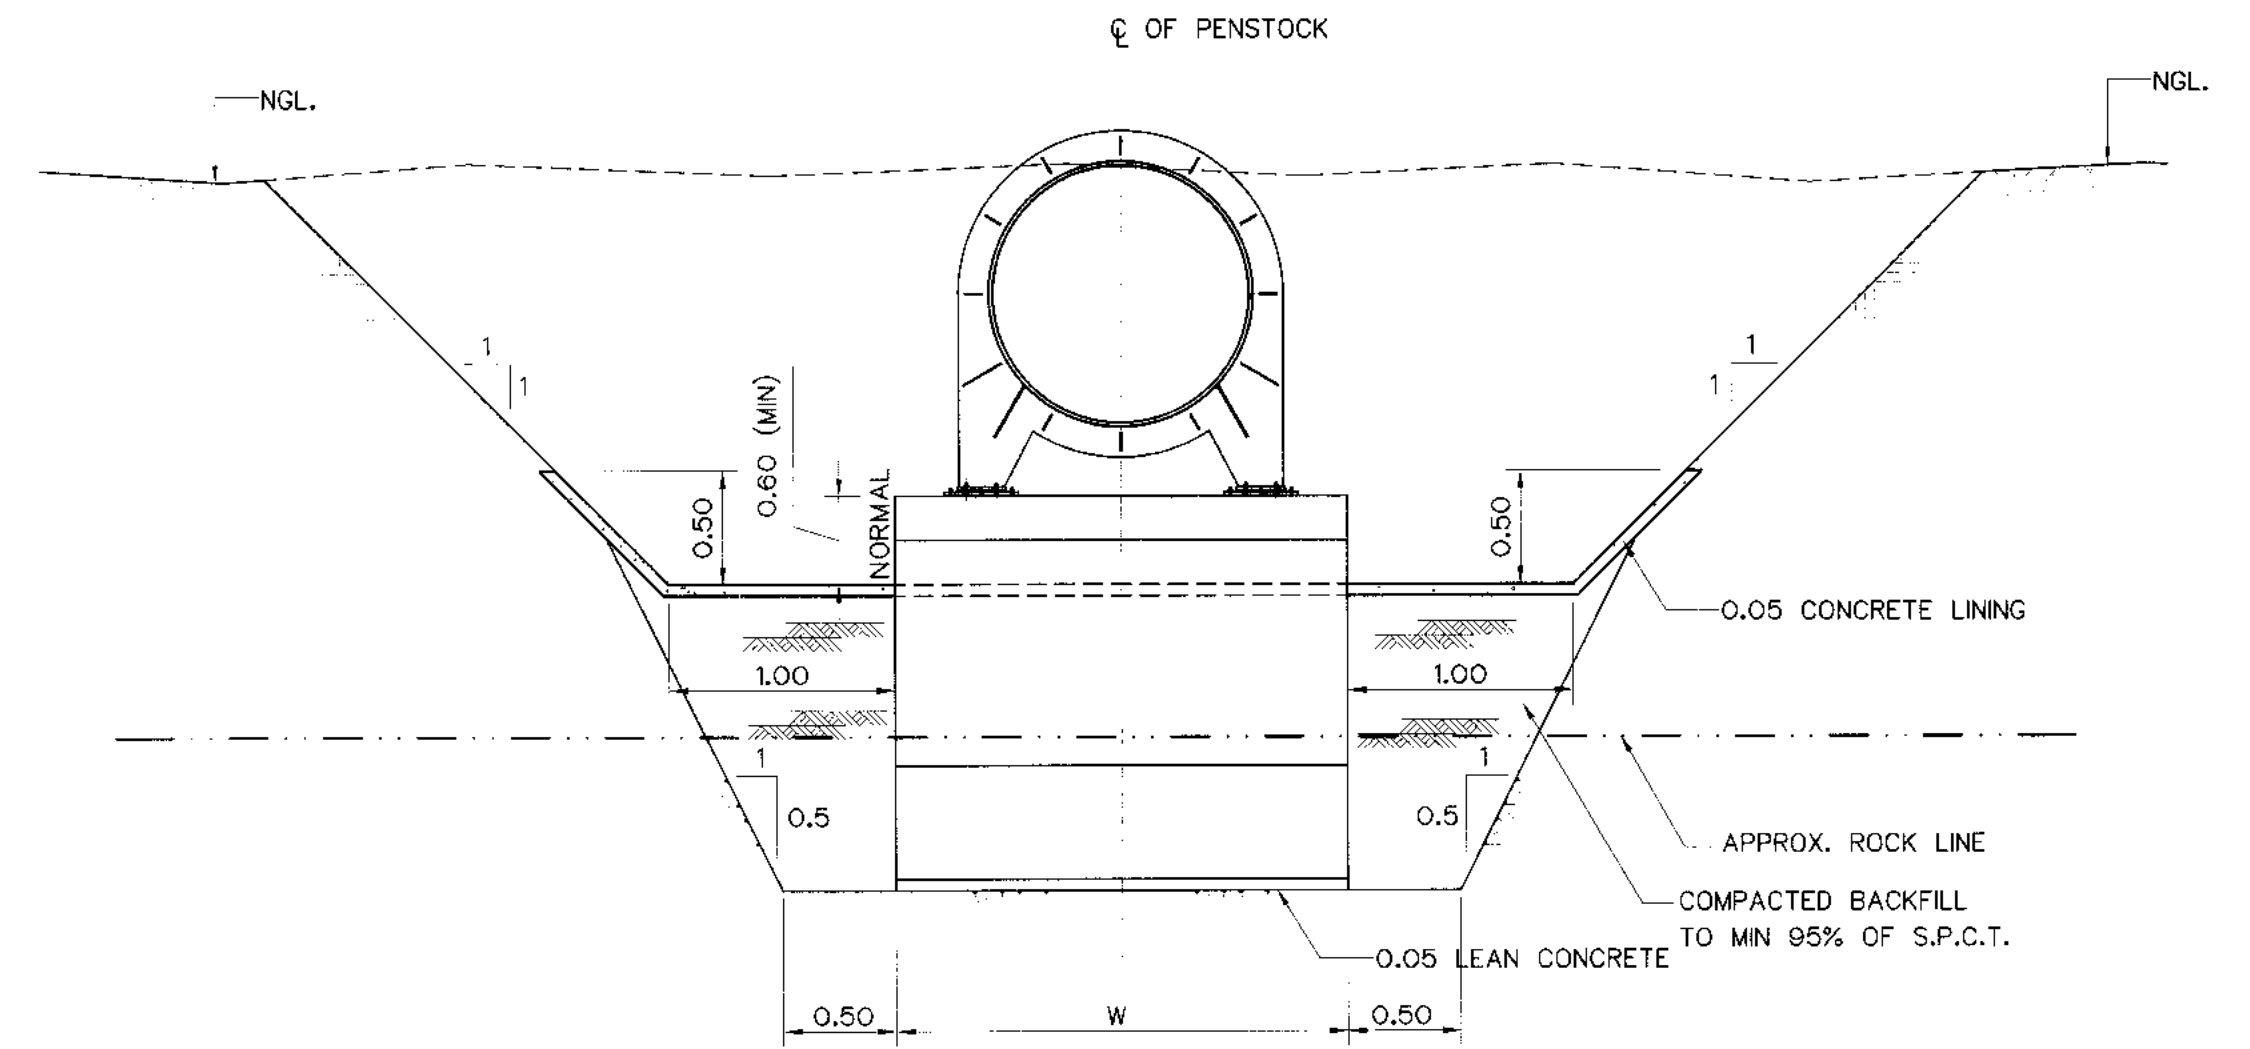

STA.0+657.065 TO 0+674.788

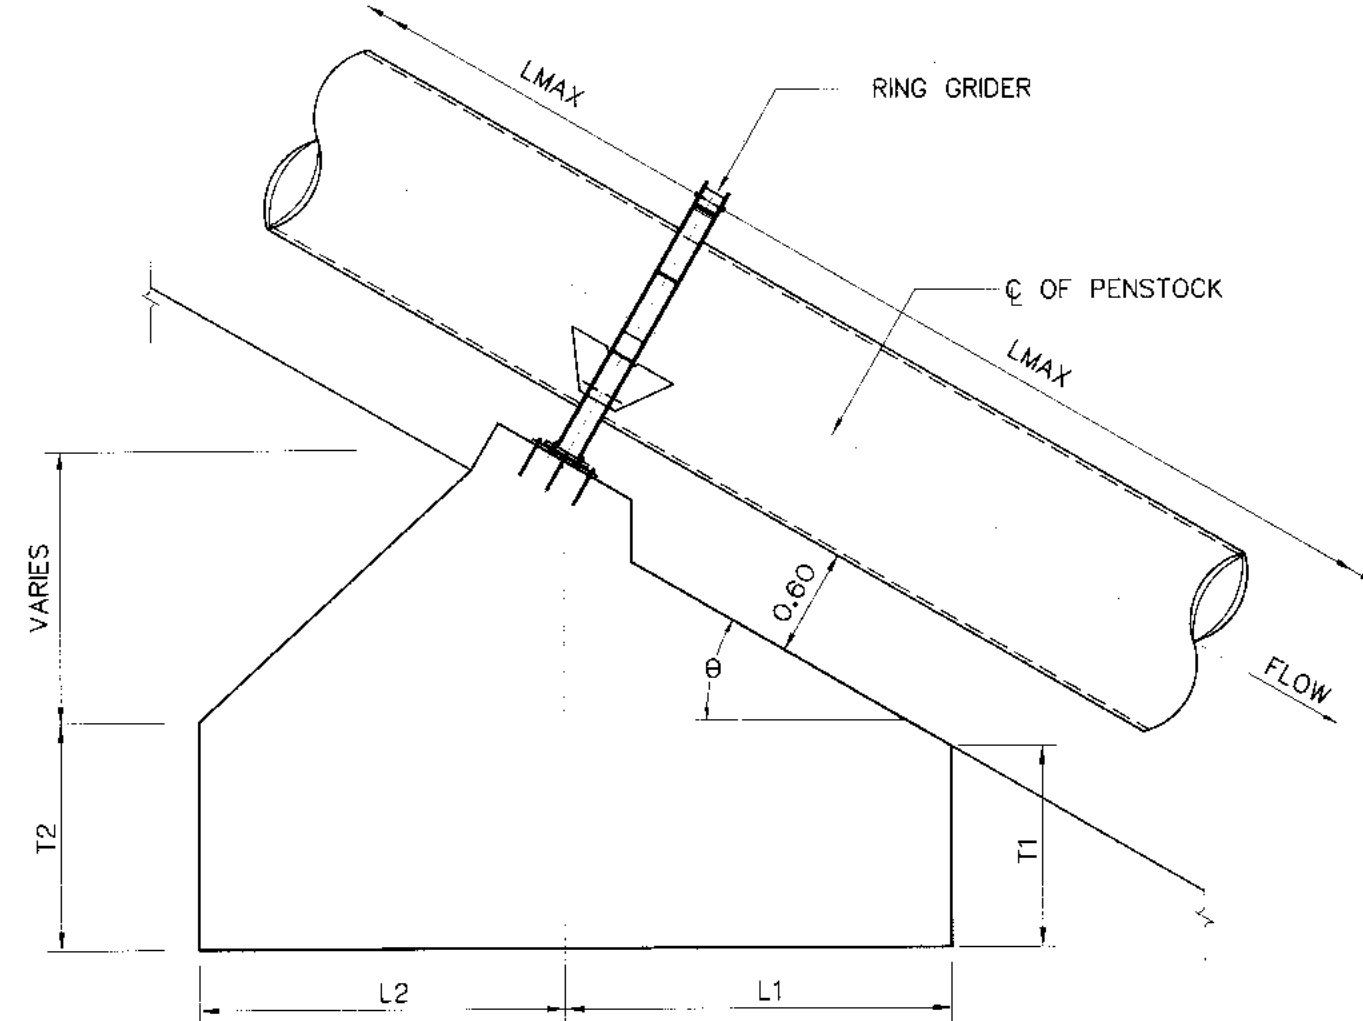

PIER TYPE 2
NOT TO SCALE

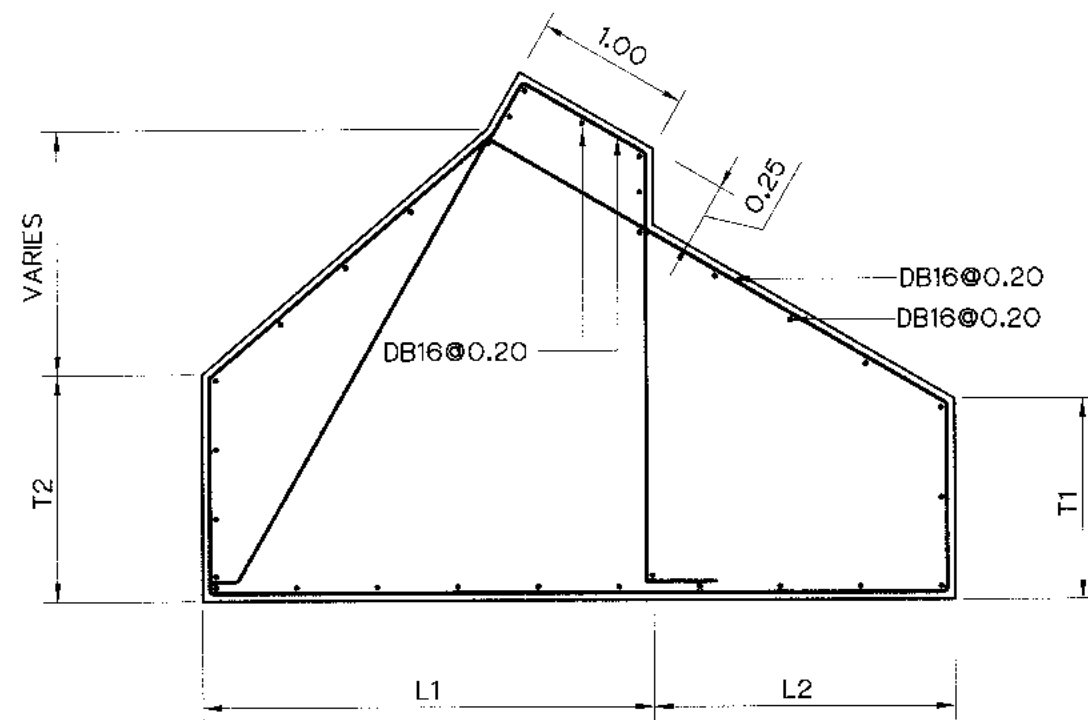


PIER (REINFORCEMENT DETAIL)


NOT TO SCALE

DIMENSIONS FOR PIER


STA. FROM	STA. TO	SLOPE (°)	L1 (m.)	L2 (m.)	T1 (m.)	T2 (m.)	W (m.)	LMAX (m.)
0+060.000	0+102.500	16.88	2.00	1.00	1.50	1.00	3.00	8.00
0+102.500	0+125.263	7.76	2.00	1.00	1.00	1.00	3.00	8.00
0+125.263	0+213.500	14.08	2.00	1.00	1.50	1.00	3.00	8.00
0+213.500	0+267.500	20.51	2.50	1.50	1.50	1.50	4.00	8.00
0+267.500	0+287.500	26.79	2.50	1.50	1.50	1.50	4.00	8.00
0+287.500	0+427.500	5.67	2.00	1.00	1.00	1.00	3.00	8.00
0+427.500	0+497.500	16.77	2.00	1.00	1.50	1.00	3.00	8.00
0+497.500	0+598.500	14.23	2.00	1.00	1.50	1.00	3.00	8.00
0+610.147	0+628.500	29.76	2.50	1.50	1.50	1.50	4.00	8.00
0+628.500	0+657.065	19.80	2.50	1.50	1.50	1.50	4.00	8.00
0+657.065	0+674.788	33.69	2.50	1.50	1.50	1.50	4.00	8.00

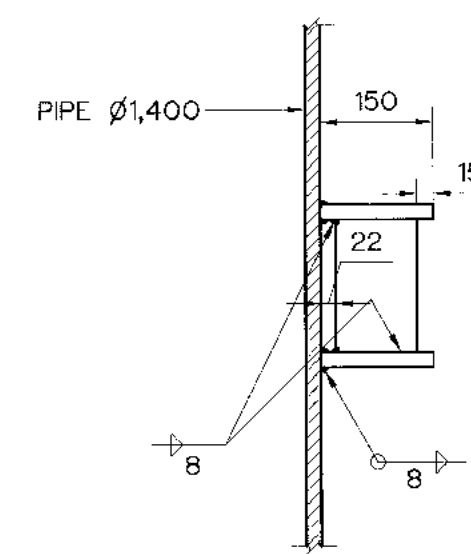

DETAIL "1"
SCALE 1:20

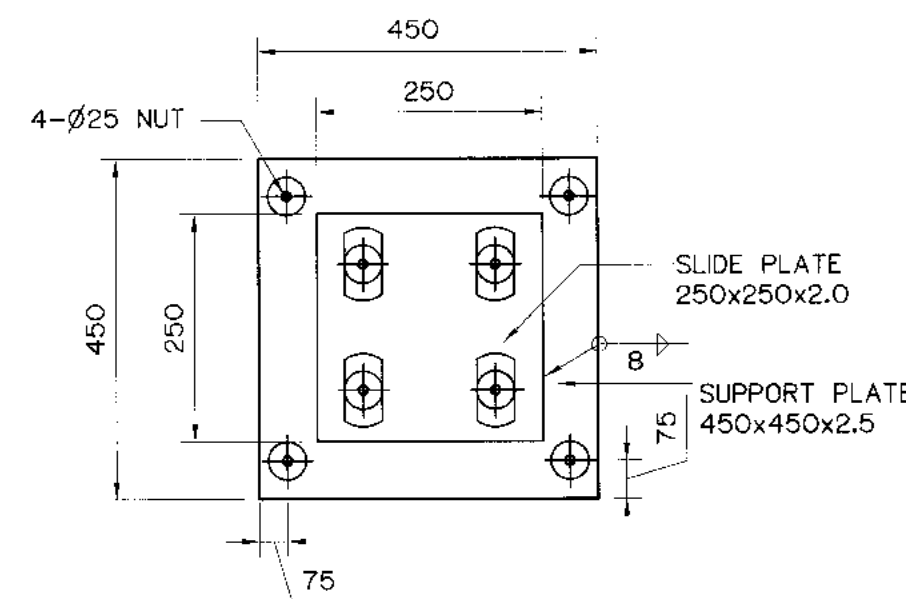


DETAIL "2"
SCALE 1:10

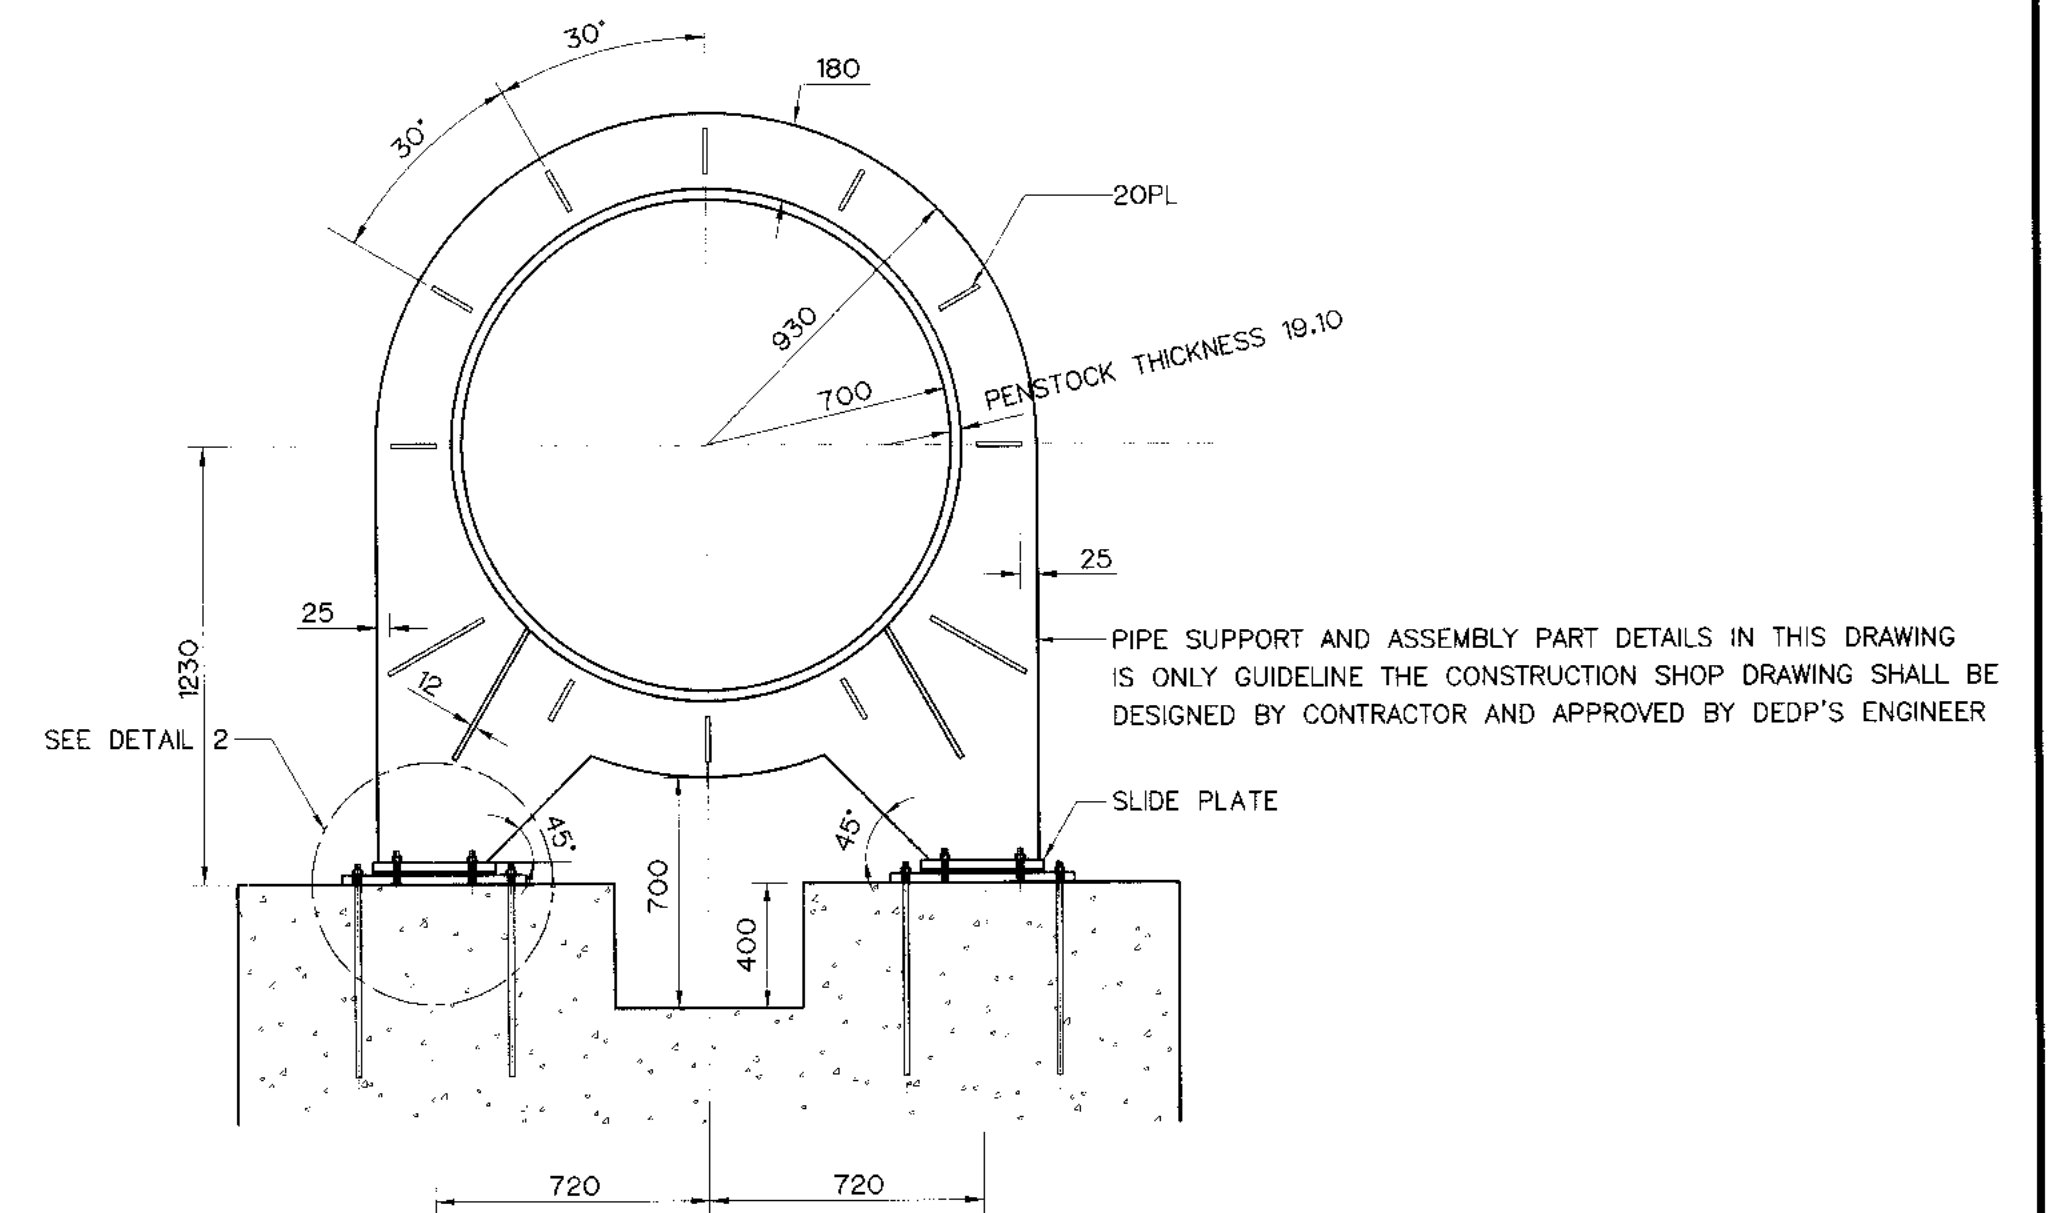


SECTION A - A
SCALE 1:20

NOTES :

1. ALL DIMENSIONS ARE IN METERS, UNLESS OTHERWISE SHOWN.
2. SYMBOLS, ABBREVIATIONS AND GENERAL NOTES SEE DWG. NO.
3. CORROSIVE PROTECTION IS WARNED TO STRICTLY FOLLOW PAINTING SPECIFICATION
4. PIPE SUPPORT AND ASSEMBLY PART DETAILS IN THIS DRAWING IS ONLY GUIDELINE THE CONSTRUCTION SHOP DRAWING SHALL BE DESIGNED BY CONTRACTOR AND APPROVED BY DEDP'S ENGINEER

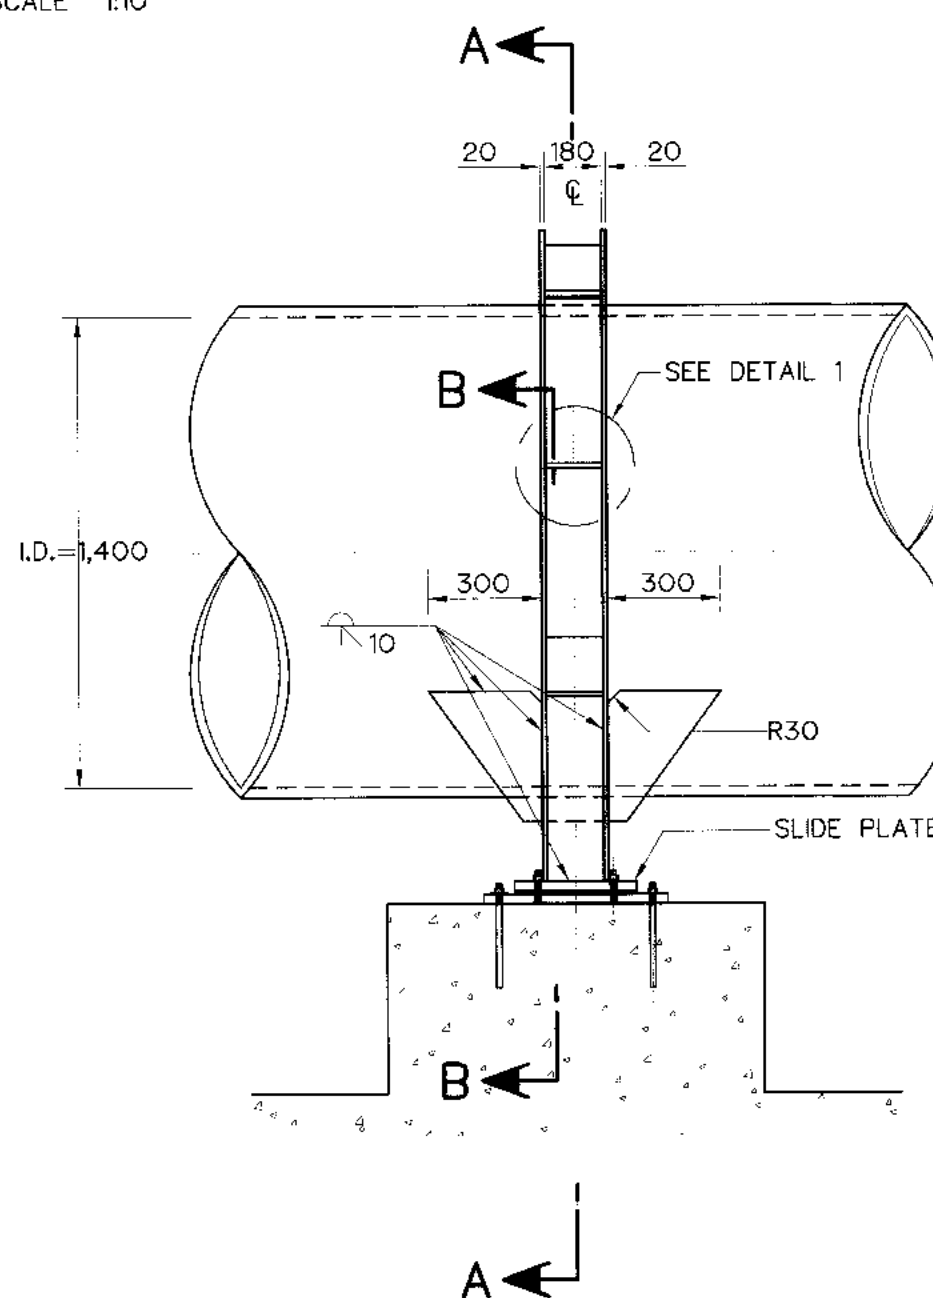

RING GIRDER FOR 1,400 I.D. PIPE

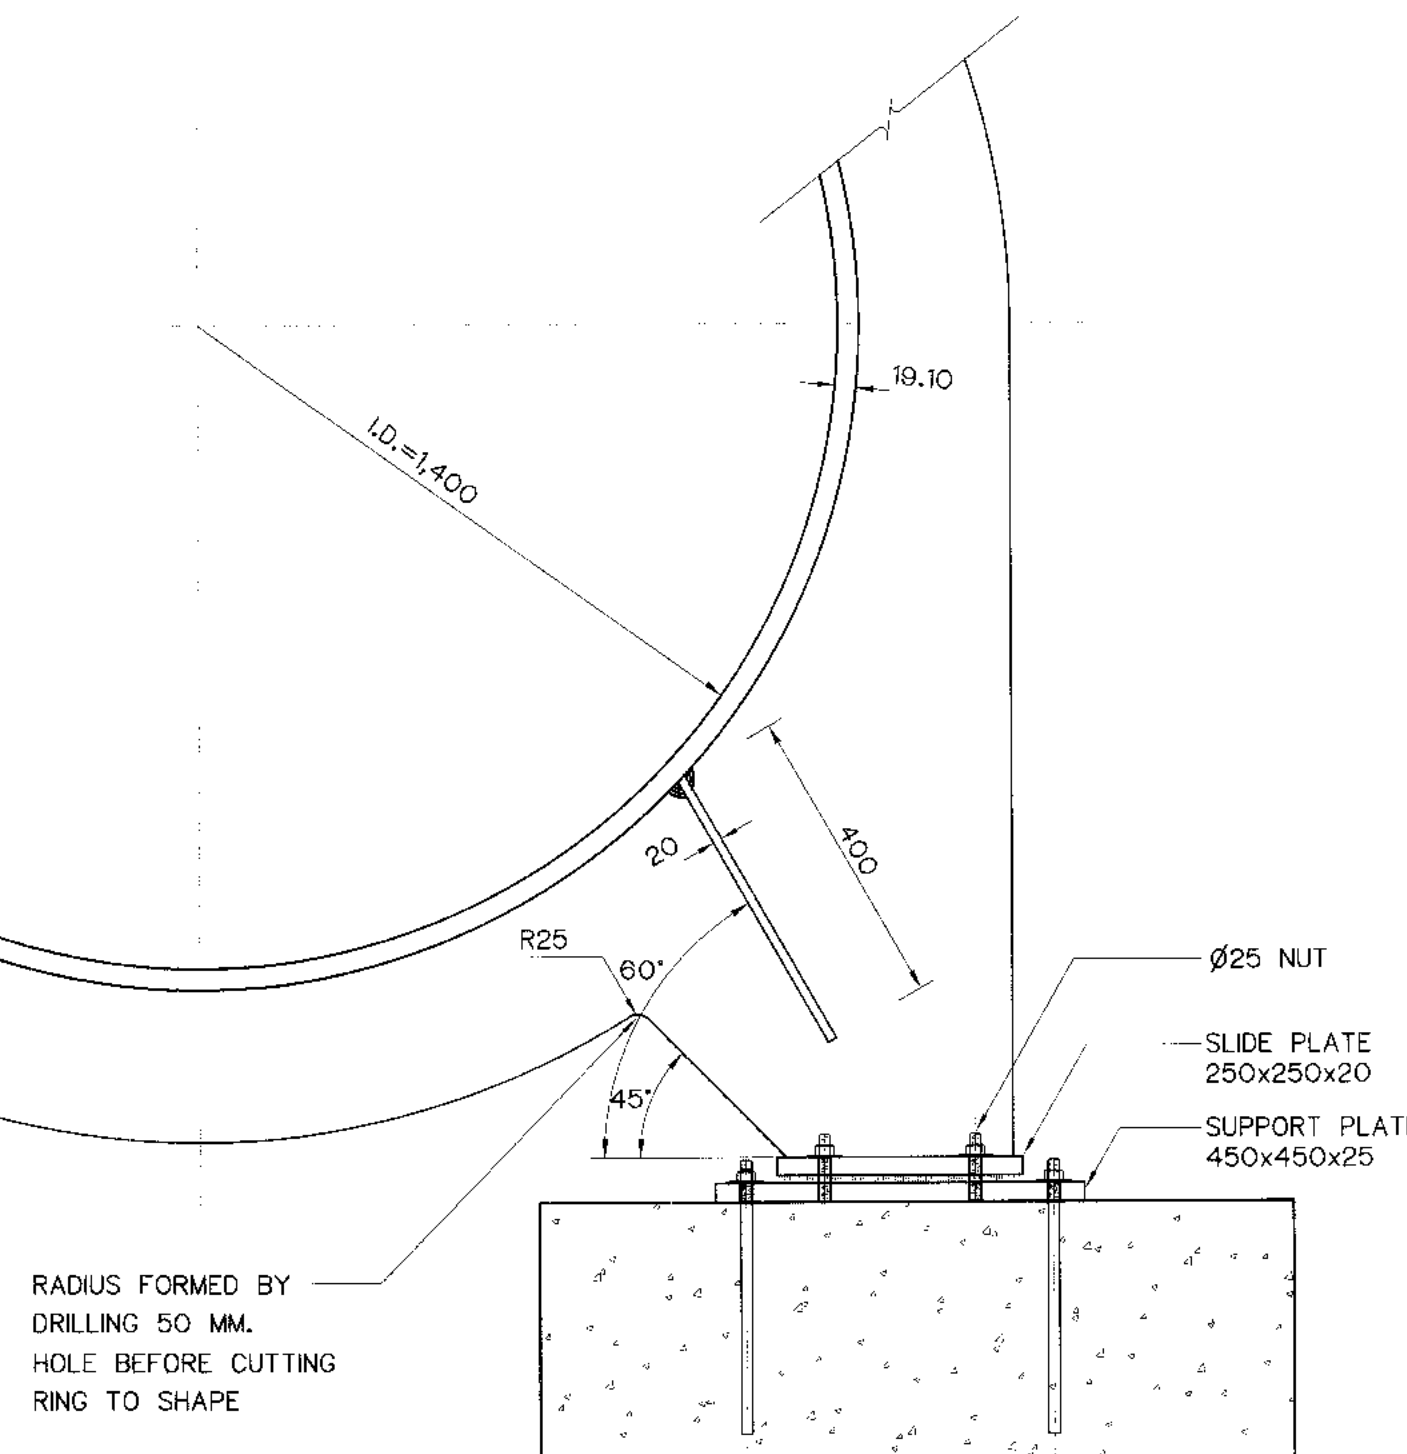


SECTION B - B


0 0.5 1.0 1.5
SCALE 1:20 METERS

3				
2				
1				
NO.	DATE	REVISIONS	CHECKED	APPROVED


KINGDOM OF THAILAND Department of Alternative Energy Development and Efficiency MINISTRY OF ENERGY	
KLONG LAM PLOK HYDROPOWER PROJECT	
CIVIL WORKS AND TRANSMISSION LINE PENSTOCK PIPE SUPPORT SECTIONS AND DETAILS	
P&C MANAGEMENT CO.,LTD. DESIGNED: <i>[Signature]</i> <i>[Signature]</i> DRAWN: <i>[Signature]</i> CHECKED: <i>[Signature]</i> PROJECT MANAGER: <i>[Signature]</i>	REVIEWED: <i>[Signature]</i> SUBMITTED: <i>[Signature]</i> RECOMMENDED: <i>[Signature]</i> APPROVED: <i>[Signature]</i> DATE: 08/03/2559
CONSULTANTS	DEDE
DRAWING NO. KLP-PS-08	SHEET NO. 66 OF 110

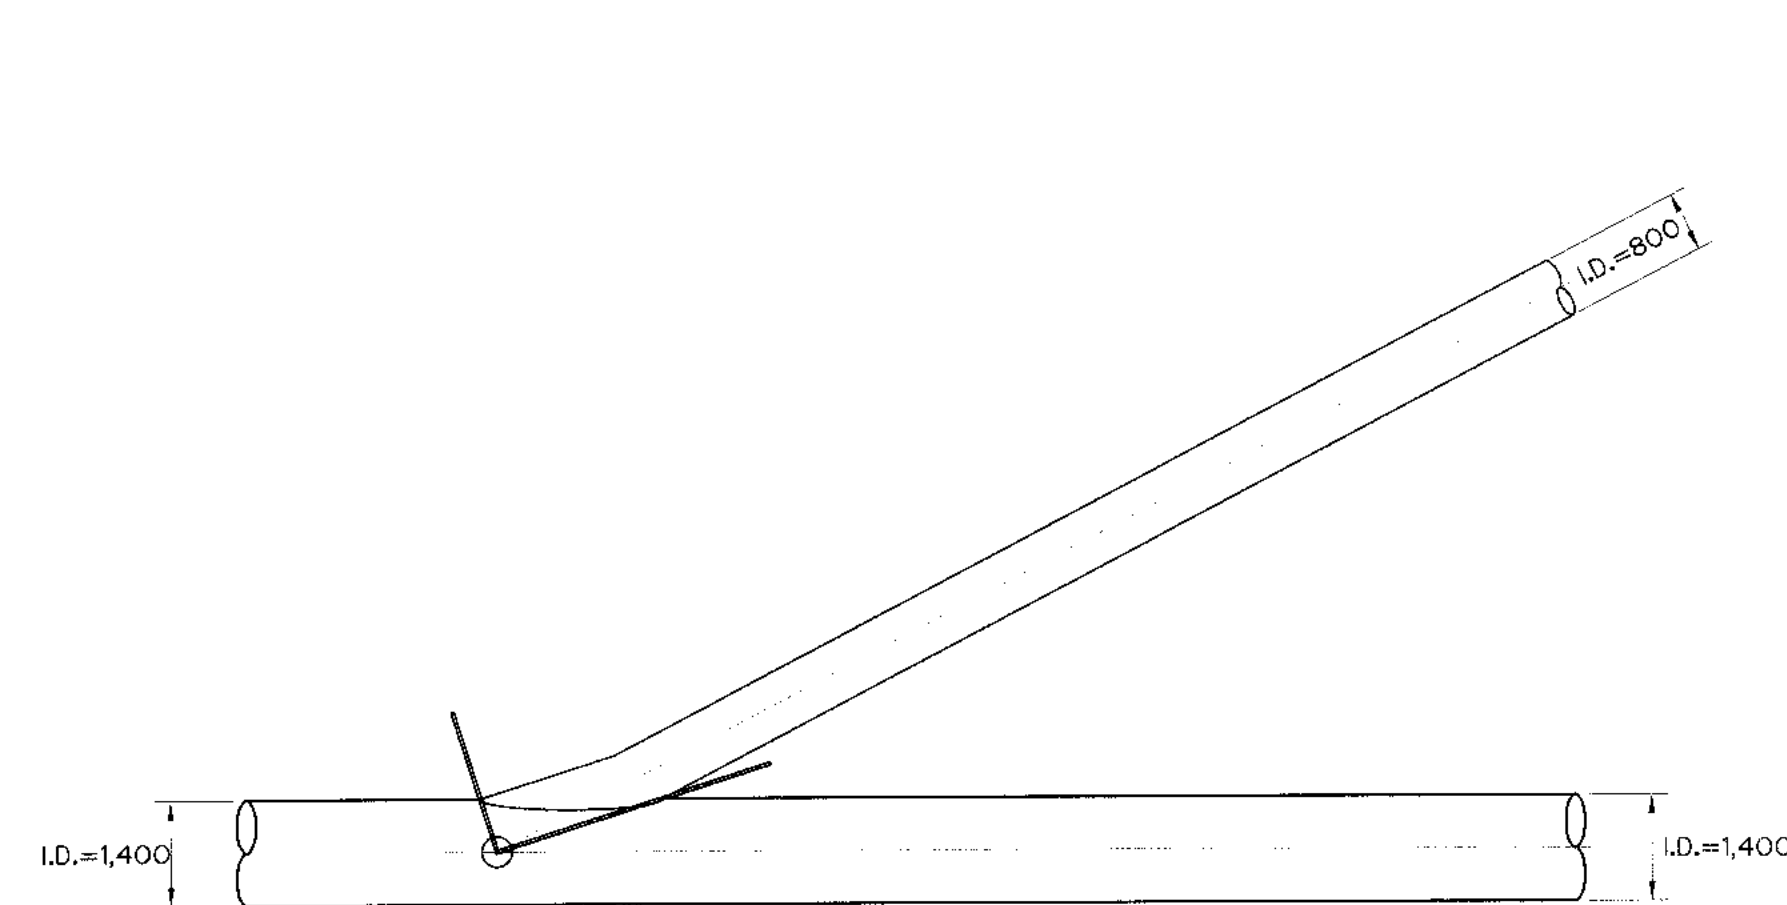


PLAN
SCALE 1:100

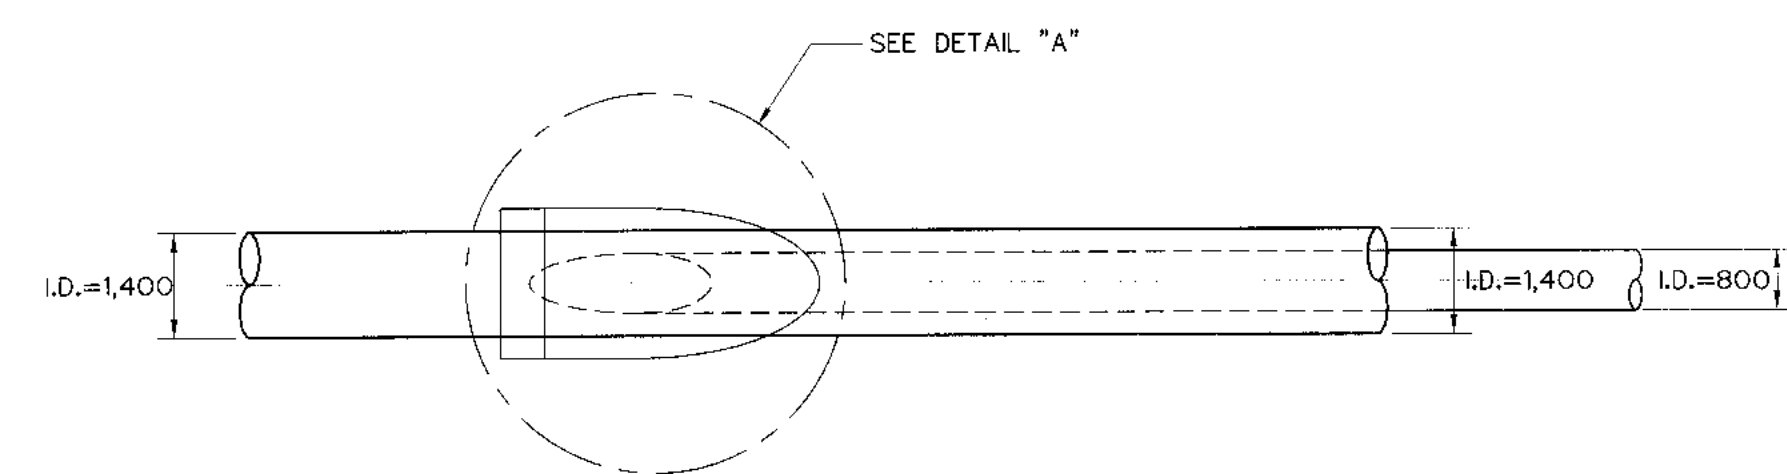


ELEVATION
SCALE 1:100

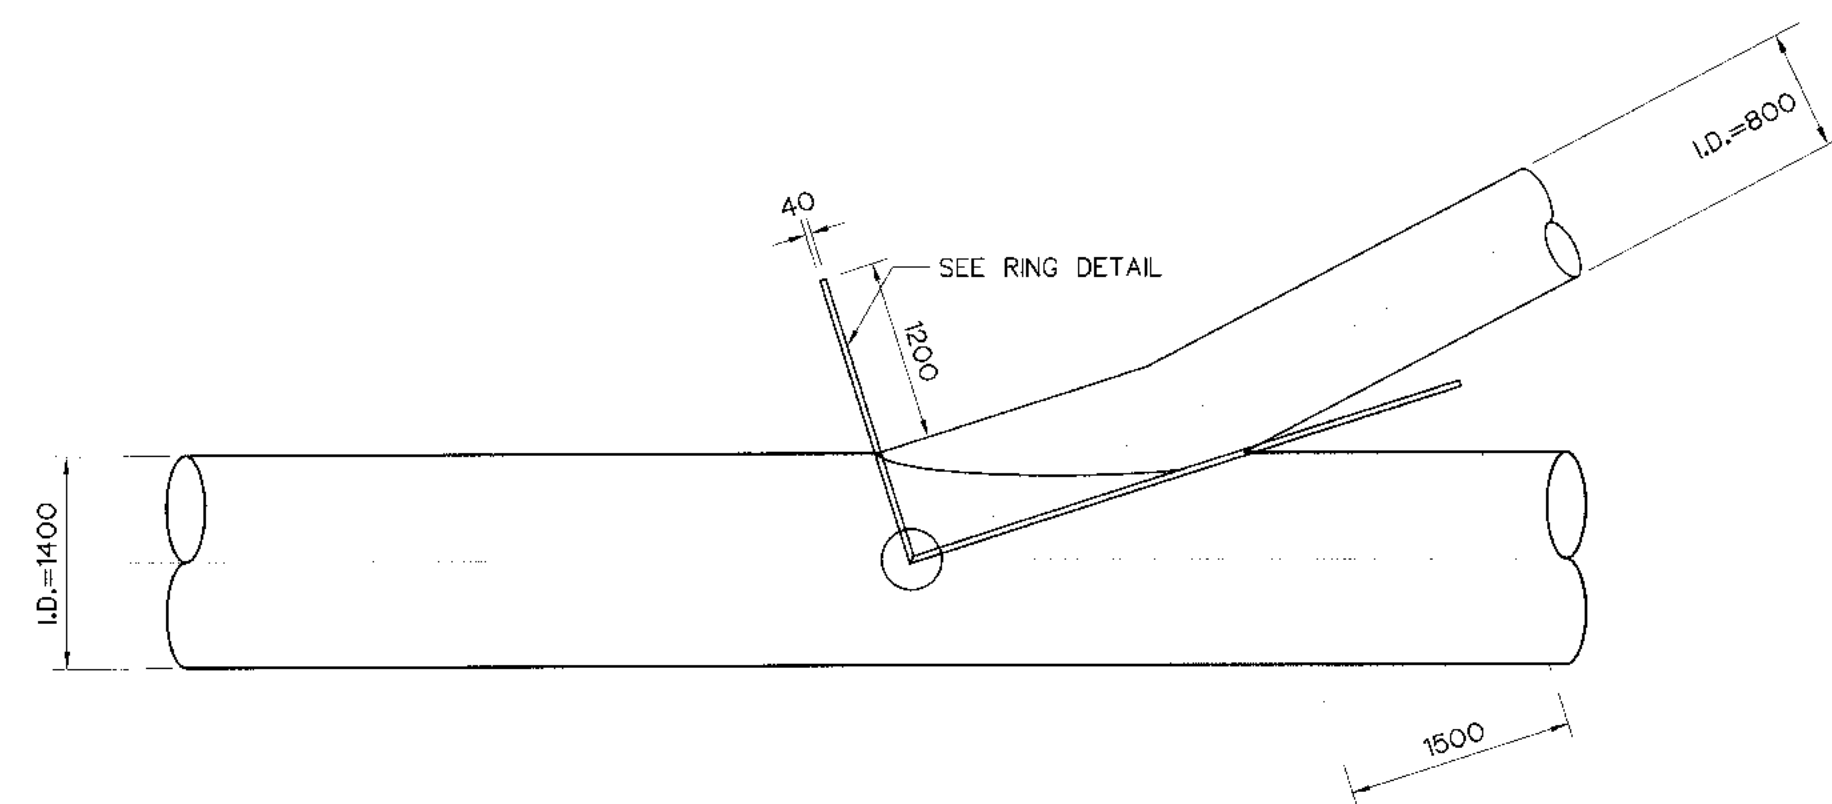


DETAIL "B"
SCALE 1:50

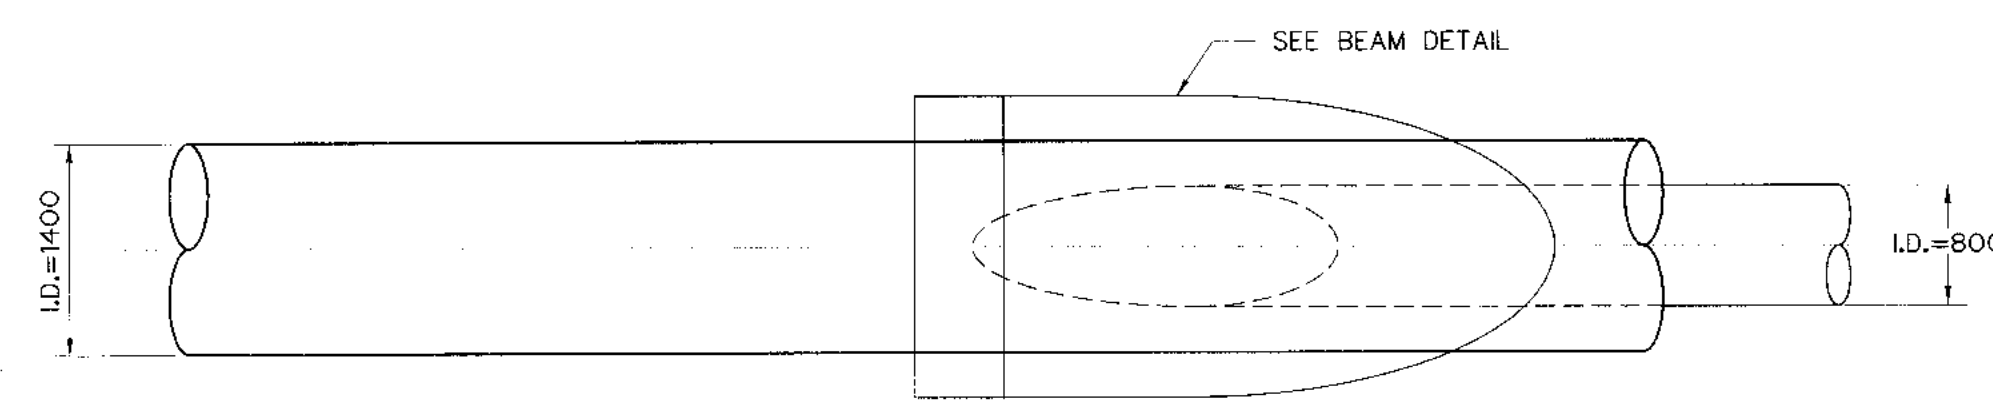


DETAIL "A"
SCALE 1:50

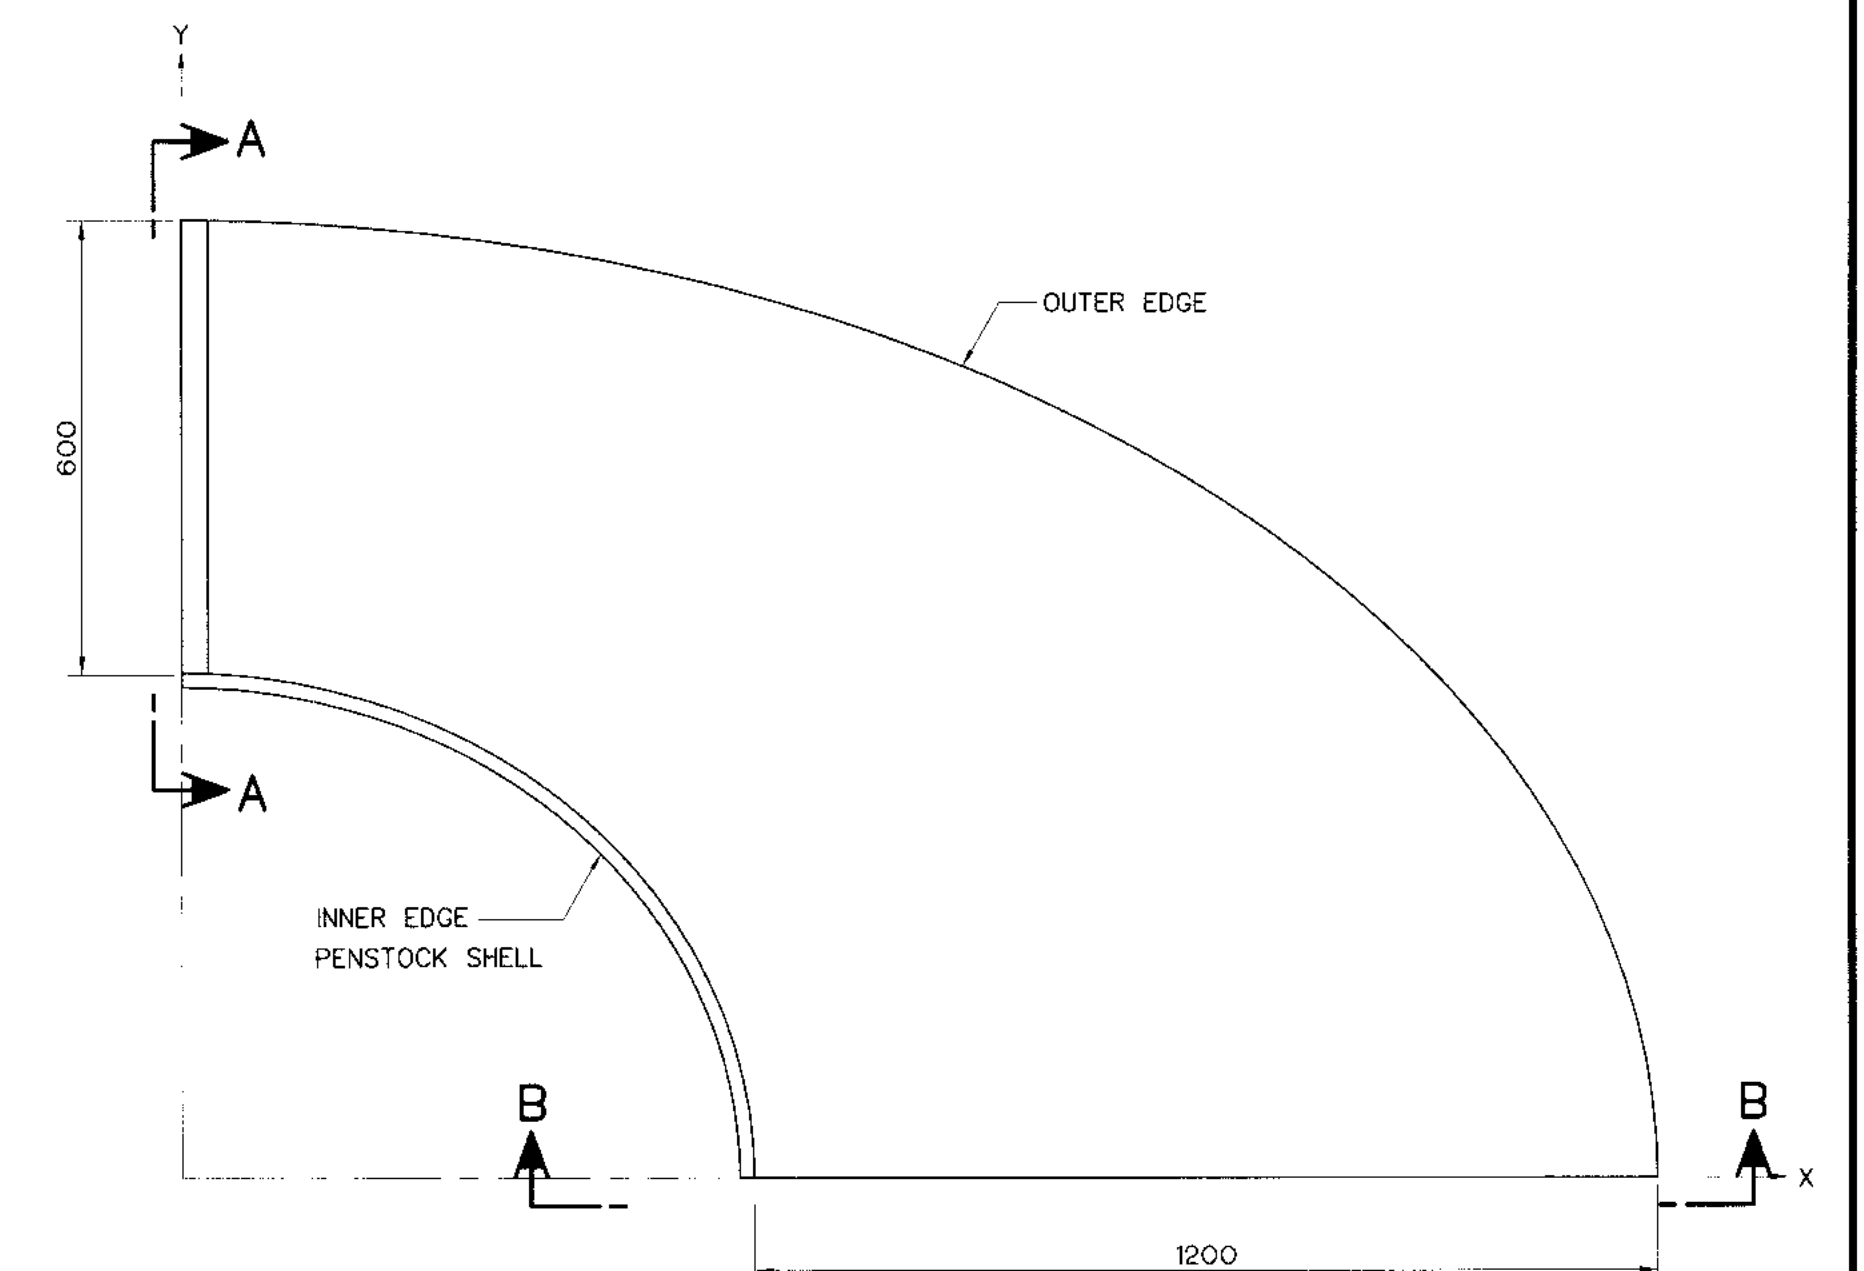


RING DETAIL
SCALE 1:10

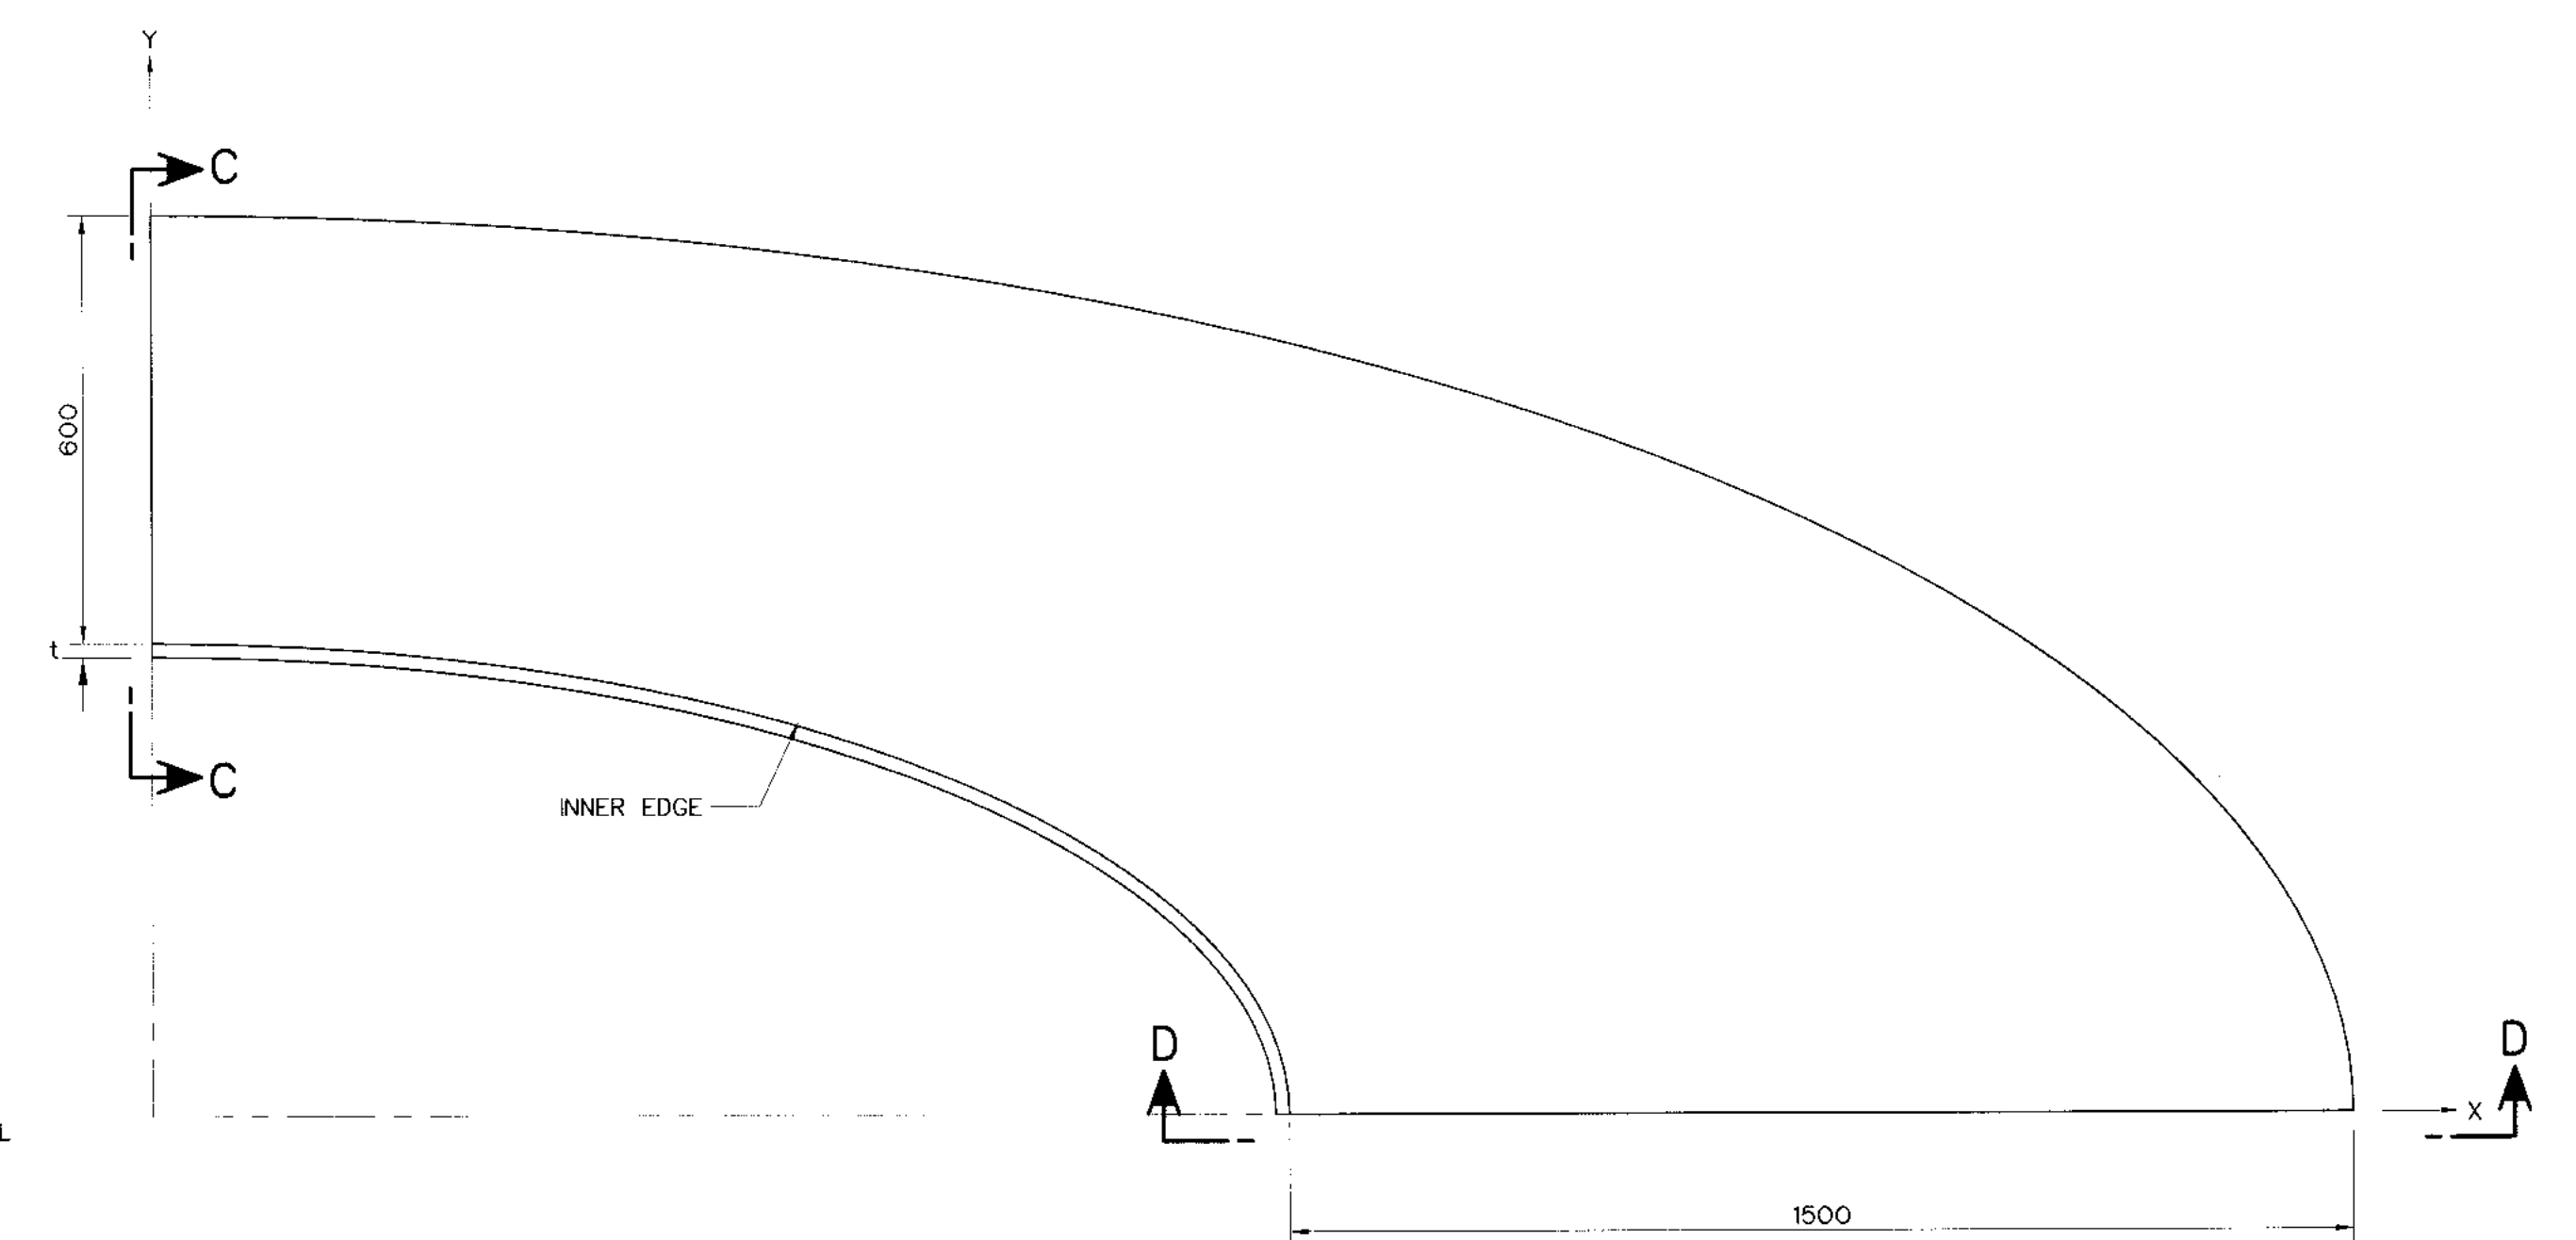


BEAM DETAIL
SCALE 1:10

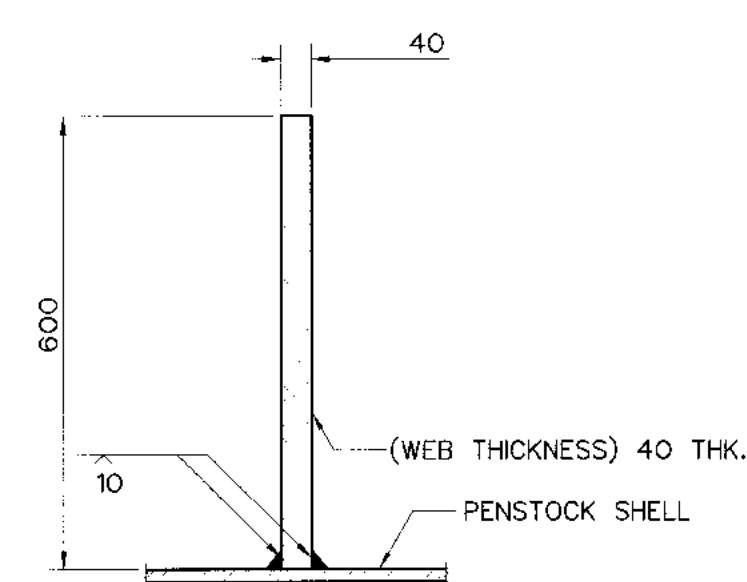


SECTION C-C
SCALE 1:10

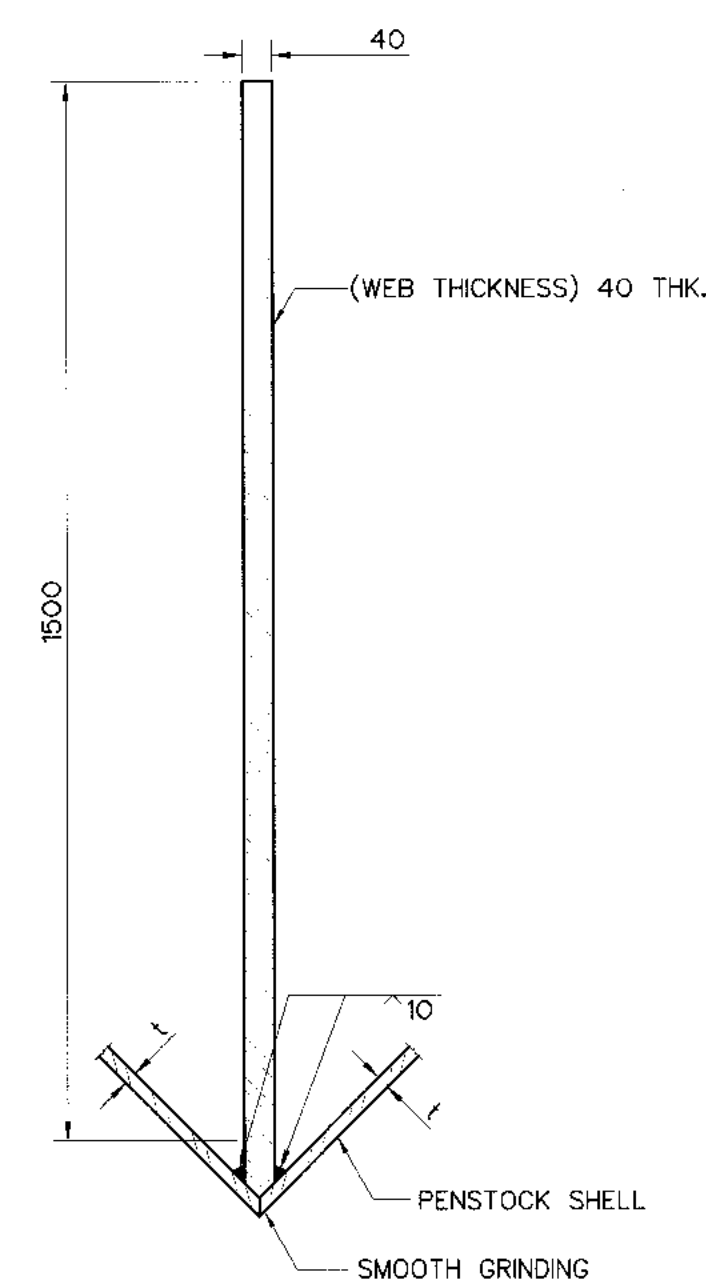

SECTION D-D
SCALE 1:10

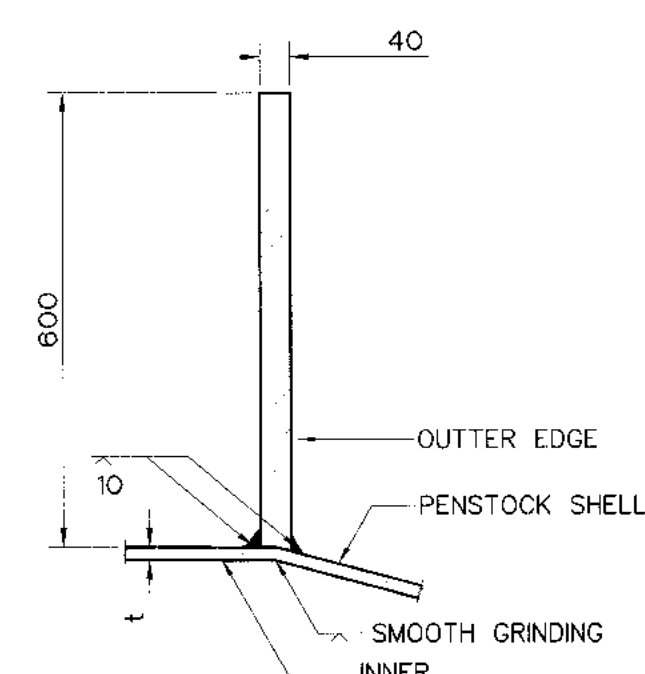


SECTION A-A
SCALE 1:10

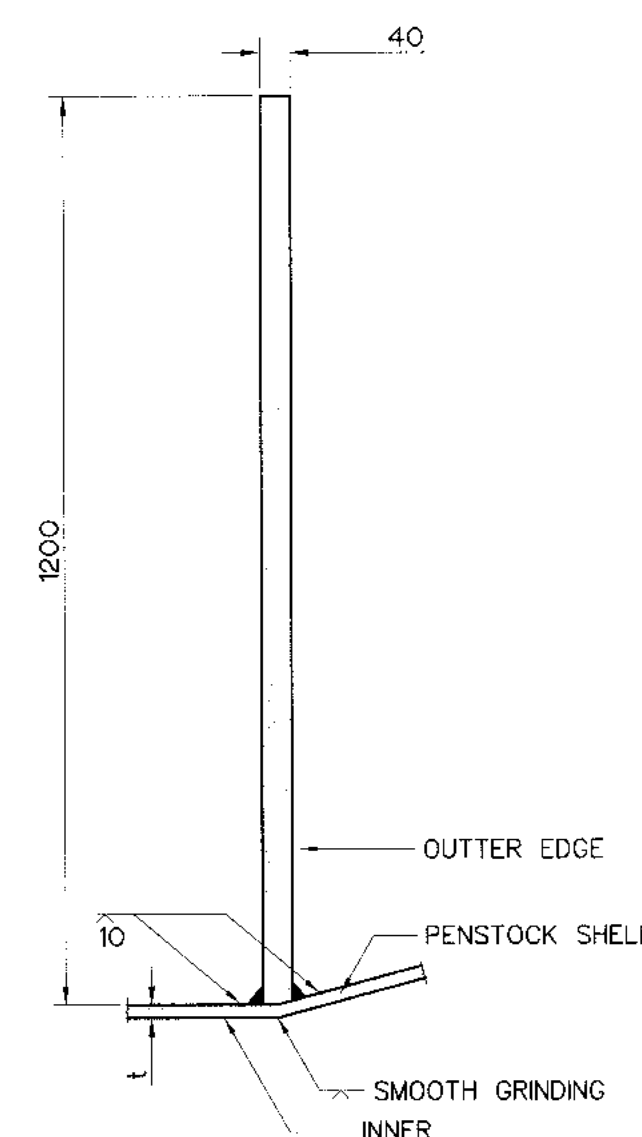

SECTION B-B
SCALE 1:10


NOTES :

1. ALL DIMENSIONS ARE IN MILLIMETERS, UNLESS OTHERWISE SHOWN.
2. SYMBOLS, ABBREVIATIONS AND GENERAL NOTES SEE DWG. NO. KLP-GN-03
3. THIS DRAWING IS ONLY GUIDELINE THE CONSTRUCTION SHOP DRAWING SHALL BE DESIGNED BY CONTRACTOR AND APPROVED BY DEDP'S ENGINEER

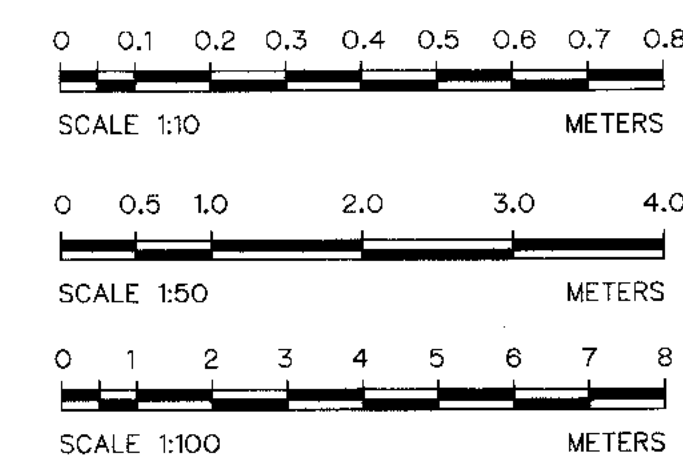


3				
2				
1				
NO.	DATE	REVISIONS	CHECKED	APPROVED


KINGDOM OF THAILAND Department of Alternative Energy Development and Efficiency MINISTRY OF ENERGY			
KLONG LAM PLOK HYDROPOWER PROJECT			
CIVIL WORKS AND TRANSMISSION LINE			
PENSTOCK			
WYE, PLAN, SECTIONS AND DETAILS AT STA.0+516.909			
P&C MANAGEMENT CO.,LTD.		Department of Alternative Energy Development and Efficiency MINISTRY OF ENERGY	
DESIGNED <i>[Signature]</i> 18/29074 28/6226		REVIEWED <i>[Signature]</i>	
DRAWN <i>[Signature]</i>		SUBMITTED <i>[Signature]</i>	
CHECKED <i>[Signature]</i> 28/6226		RECOMMENDED <i>[Signature]</i>	
APPROVED <i>[Signature]</i>		APPROVED <i>[Signature]</i>	
PROJECT MANAGER		DATE	
CONSULTANTS		DEDE	
DRAWING NO.		SHEET NO.	
KLP-PS-09		67 OF 110	

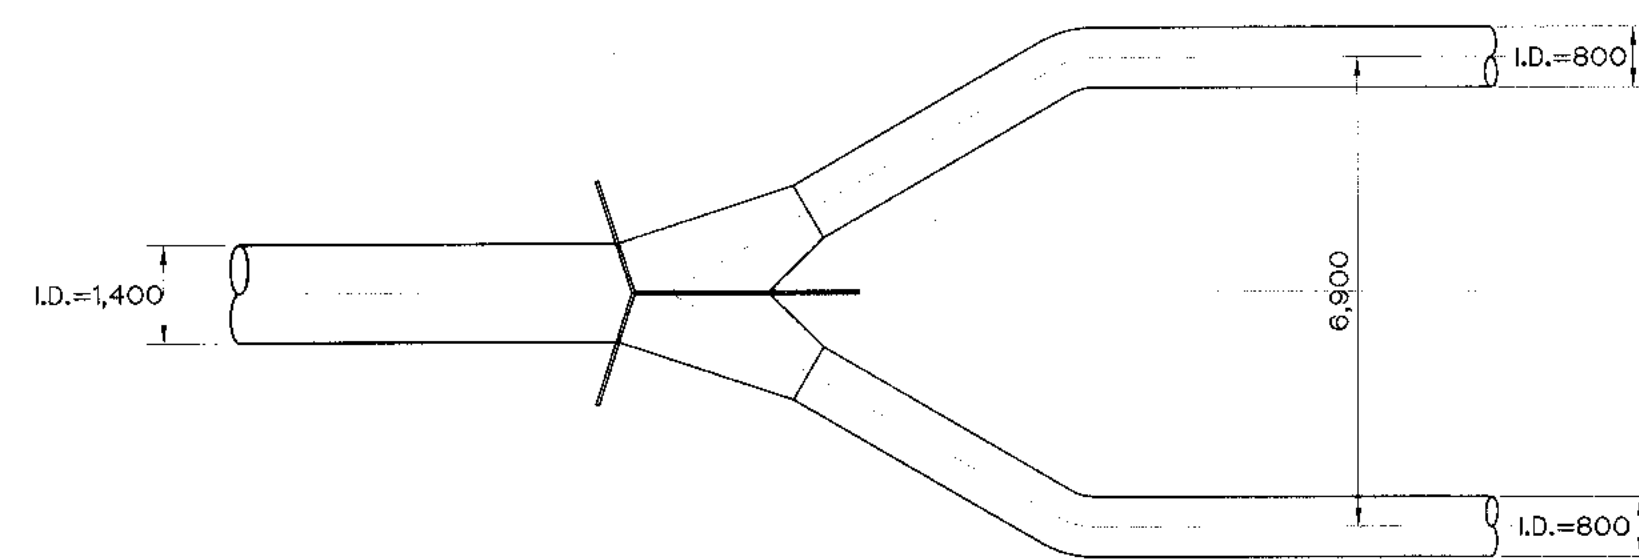


PLAN
SCALE 1:100

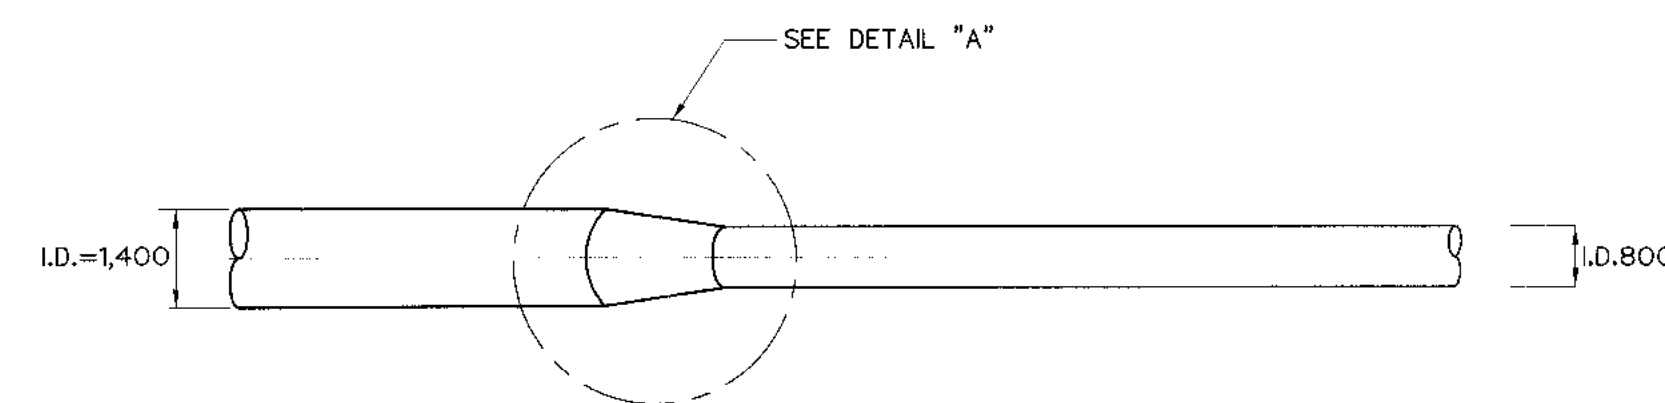


ELEVATION
SCALE 1:100

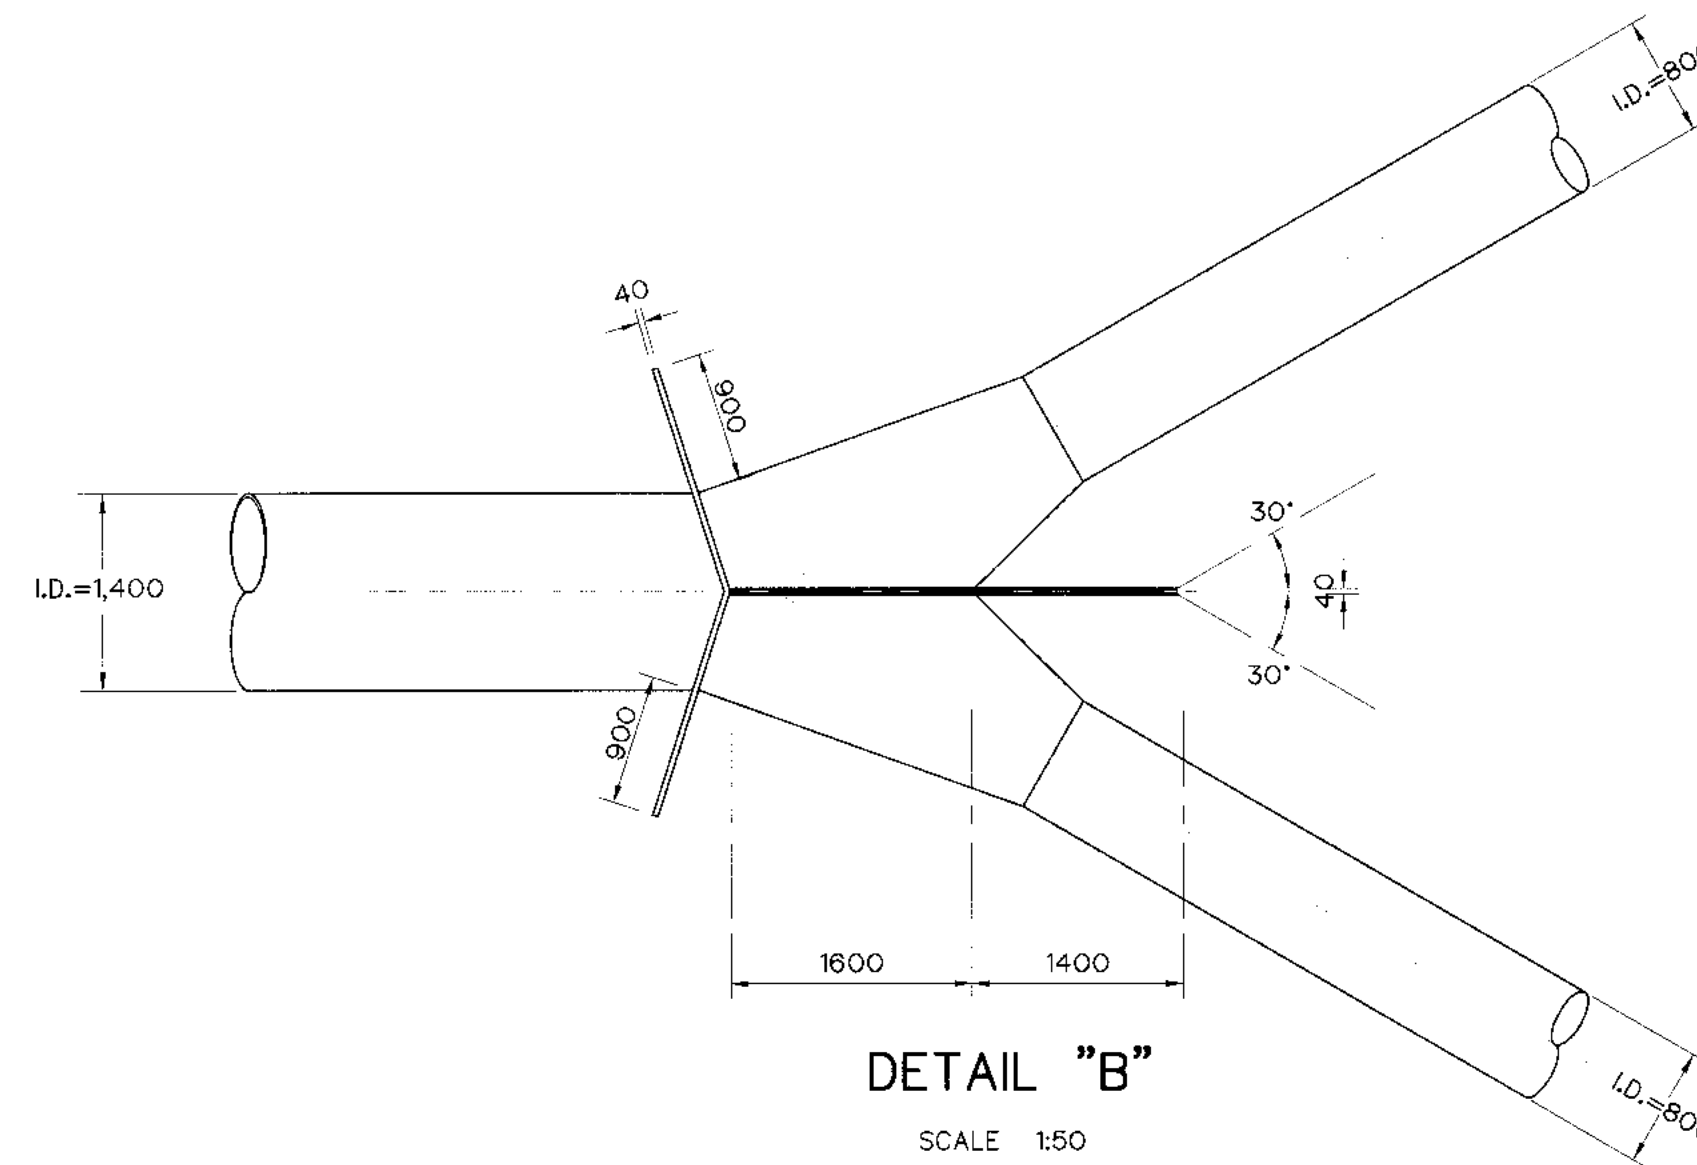


DETAIL "B"
SCALE 1:50

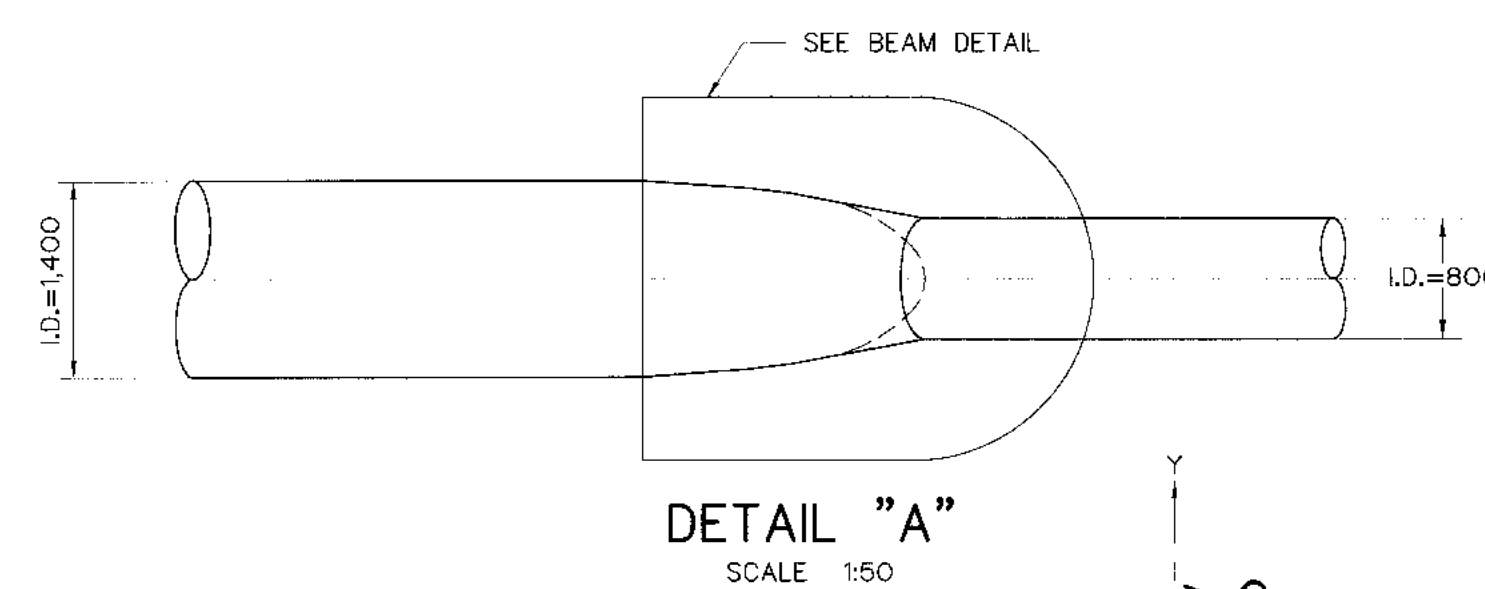


DETAIL "A"
SCALE 1:50

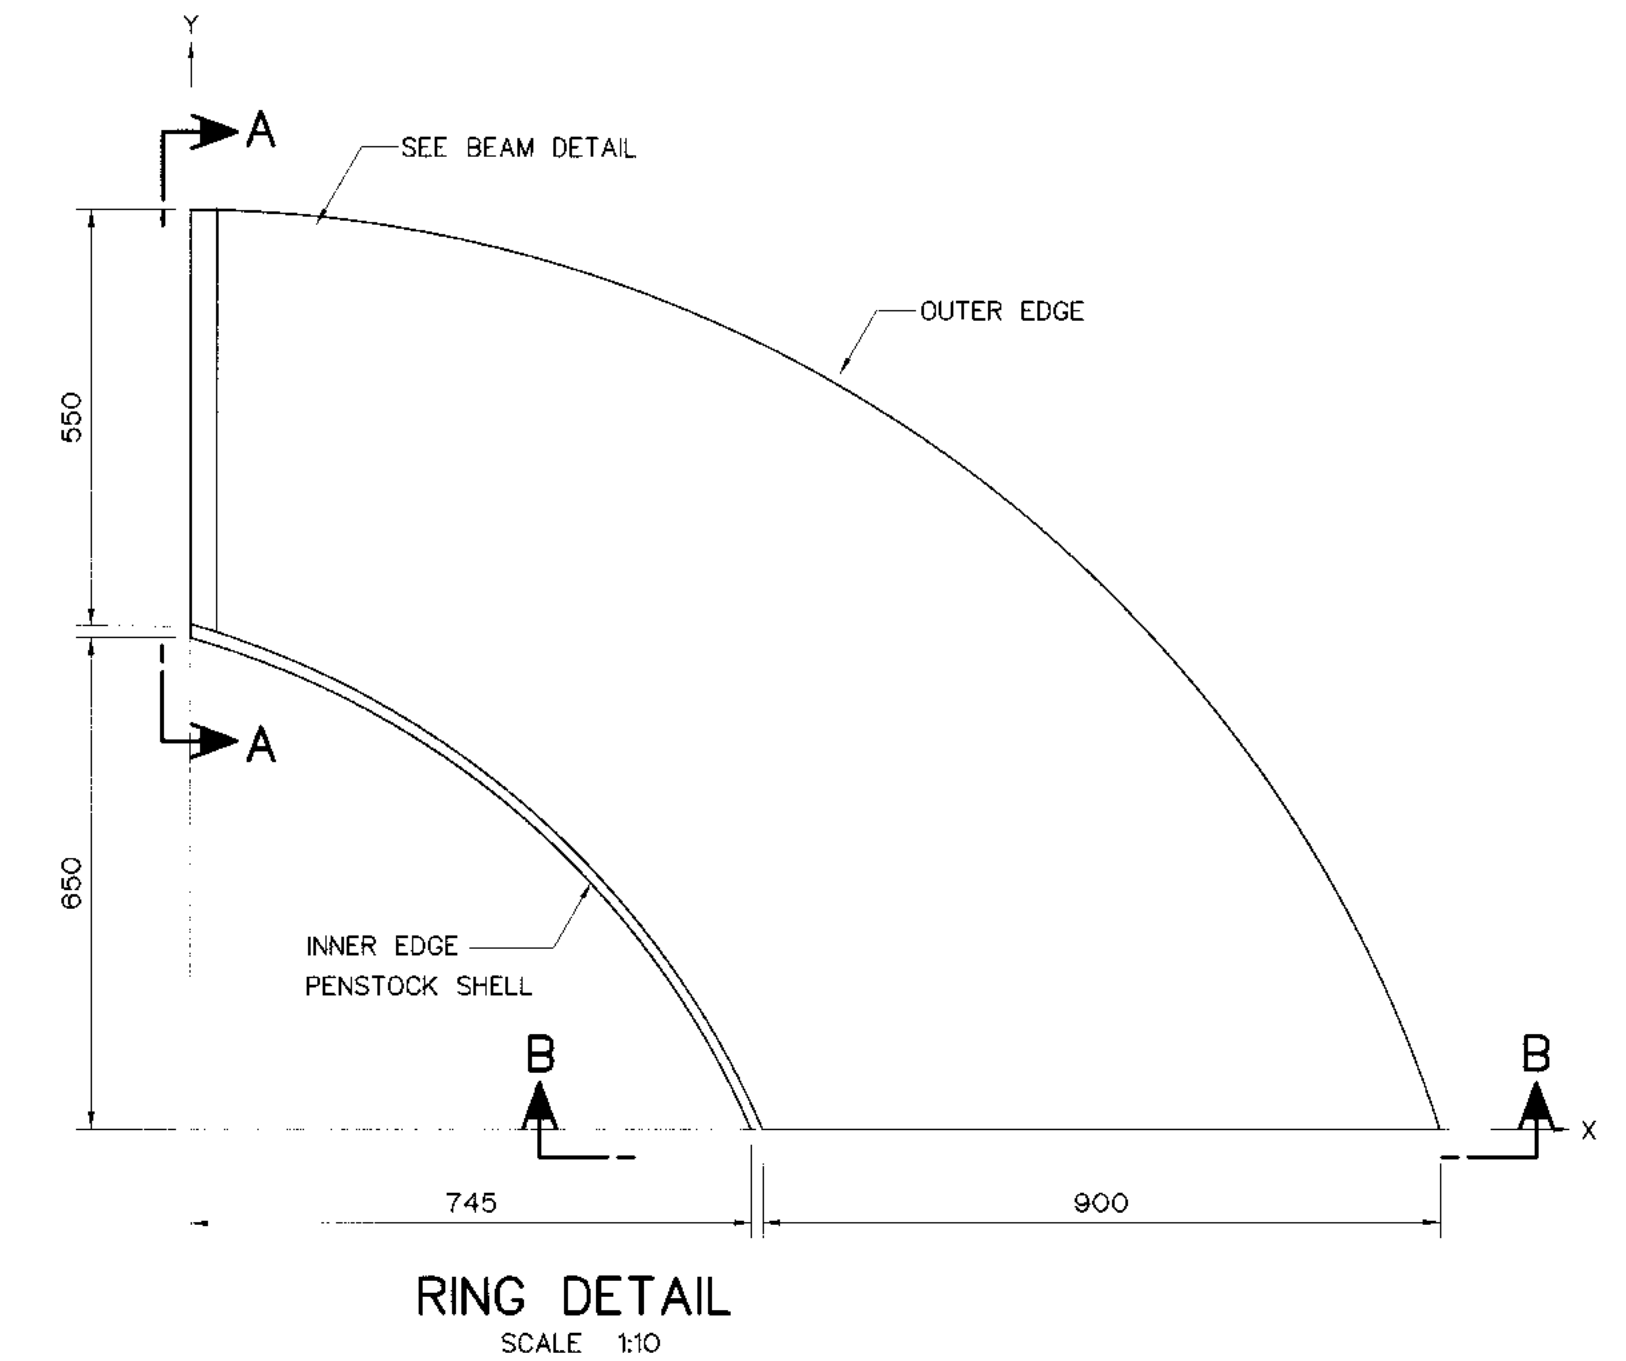


RING DETAIL
SCALE 1:10

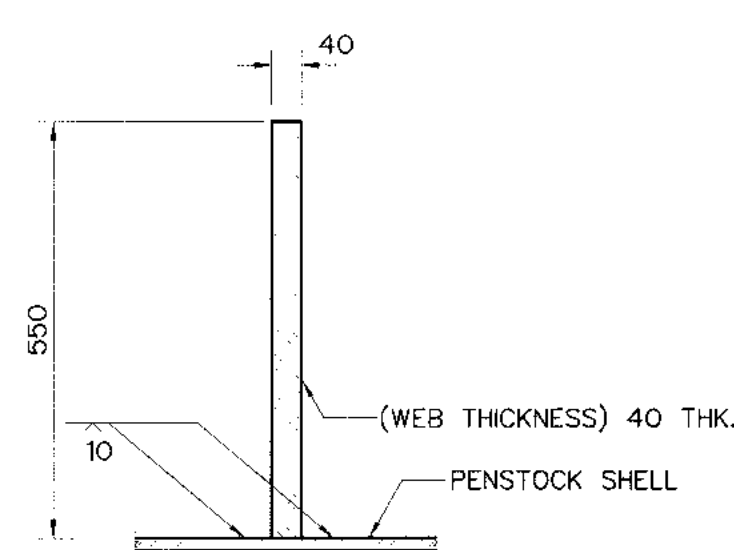


SECTION C-C
SCALE 1:10

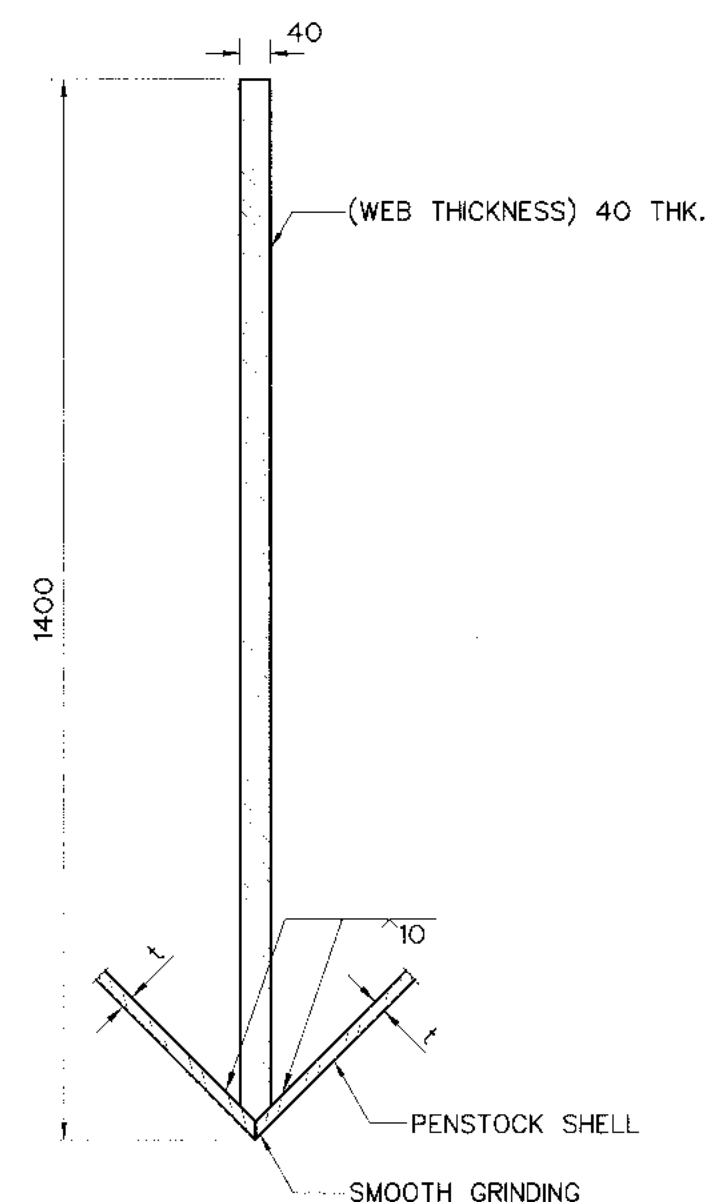

SECTION D-D
SCALE 1:10

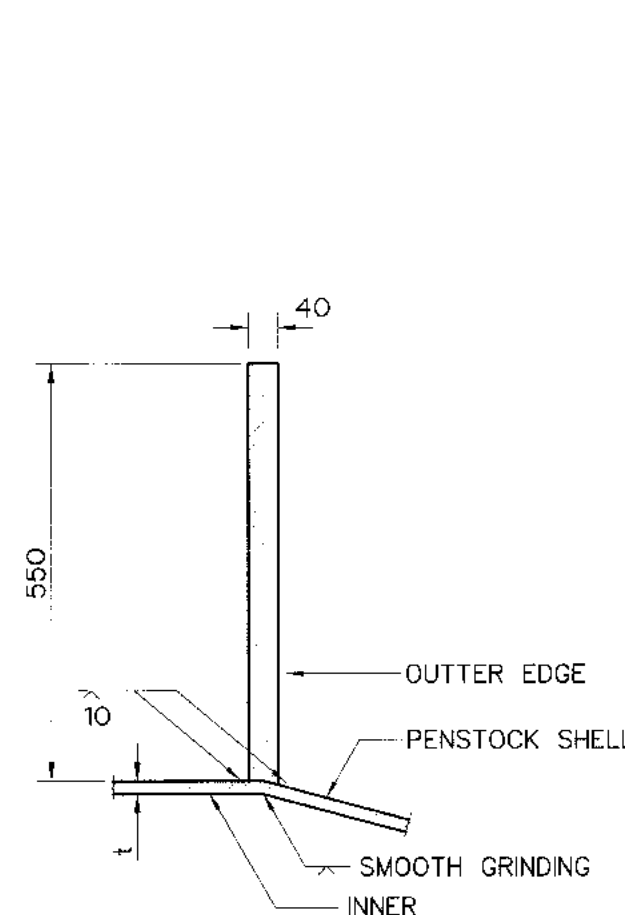

SECTION A-A
SCALE 1:10

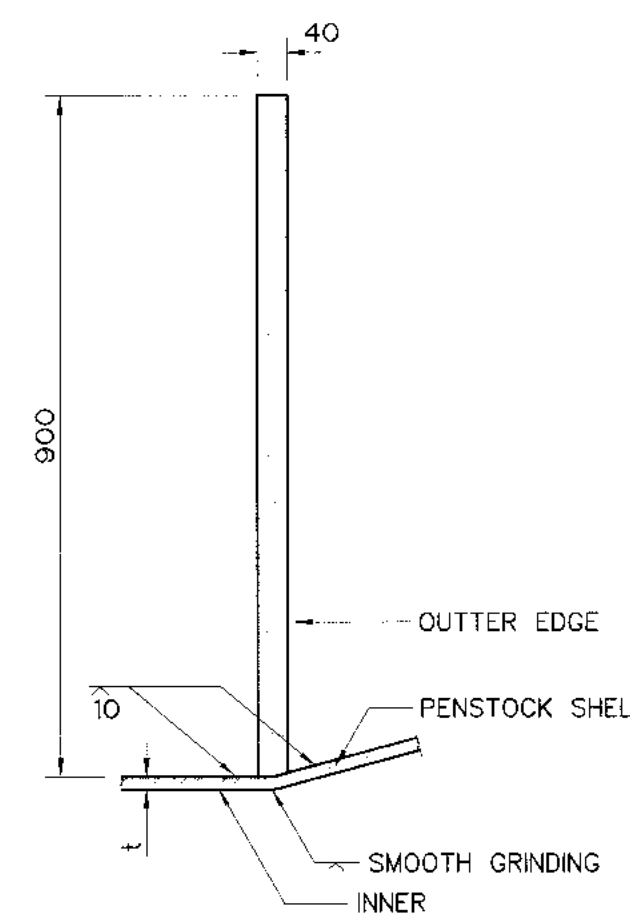


SECTION B-B
SCALE 1:10



BEAM DETAIL
SCALE 1:10

NOTES :


1. ALL DIMENSIONS ARE IN MILLIMETERS, UNLESS OTHERWISE SHOWN.
2. SYMBOLS, ABBREVIATIONS AND GENERAL NOTES SEE DWG. NO. KLP-GN-03
3. THIS DRAWING IS ONLY GUIDELINE THE CONSTRUCTION SHOP DRAWING SHALL BE DESIGNED BY CONTRACTOR AND APPROVED BY DEDP'S ENGINEER

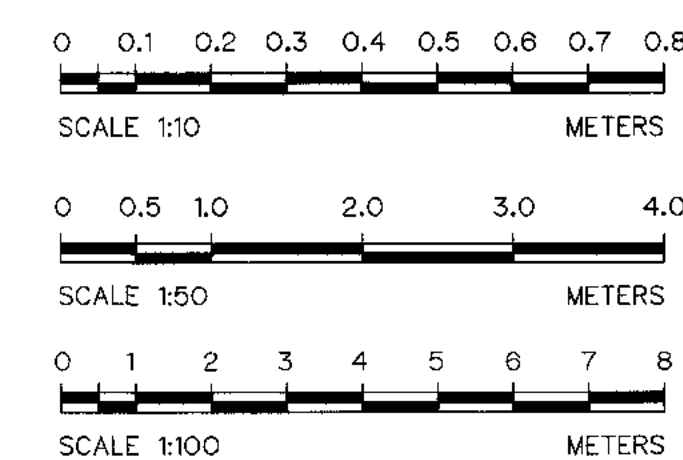

3				
2				
1				
NO.	DATE	REVISIONS	CHECKED	APPROVED

CONSULTANTS DEDE

KINGDOM OF THAILAND Department of Alternative Energy Development and Efficiency MINISTRY OF ENERGY	
KLONG LAM PLOK HYDROPOWER PROJECT	
CIVIL WORKS AND TRANSMISSION LINE PENSTOCK	
WYE, PLAN, SECTIONS AND DETAILS AT STA.0+678.000	
DESIGNED <i>[Signature]</i> 08.20074 081.6226 DRAWN <i>[Signature]</i> CHECKED <i>[Signature]</i> 081.6226 PROJECT MANAGER	REVIEWED <i>[Signature]</i> SUBMITTED <i>[Signature]</i> RECOMMENDED <i>[Signature]</i> APPROVED <i>[Signature]</i> 08/03/2559 DATE
P&C MANAGEMENT CO.,LTD.	DRAWING NO. KLP-PS-10 SHEET NO. 68 OF 110

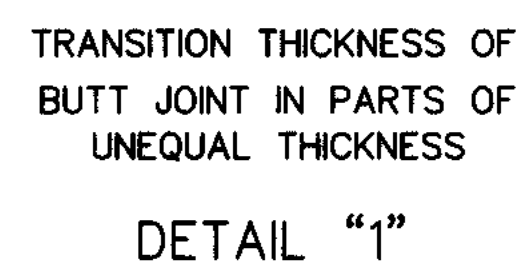

ITEM	DESCRIPTION	MATERIAL	QUANT.	REMARKS
1.	PENSTOCK	ASTM A-283, GRADE D	—	—
2.	PENSTOCK	ASTM A-283, GRADE D	1	NOTE 2 & 3
3.	INNER SLEEVE	ASTM A-283, GRADE D	1	NOTE 2 & 4
4.	GRAND RING	ASTM A-283, GRADE D	1	SEAMLESS, NOTE 3
5.	OUTER RING	ASTM A-283, GRADE D	1	SEAMLESS, NOTE 3
6.	STUFFING BOX	ASTM A-283, GRADE D	1	NOTE 2 & 3
7.	DOUBLING PLATE	ASTM A-283, GRADE D	1	NOTE 2 & 3
8.	OUTER SLEEVE	ASTM A-283, GRADE D	1	NOTE 2 & 3
9.	PACKING STOPPER	ASTM A-283, GRADE D	1	NOTE 2 & 3
10.	Ø25 mm. BOLTS	ASTM A-325	32	—
11.	Ø25 mm. NUT	ASTM A-325	72	—
12.	Ø25 mm. WASHER	ASTM A-325	72	—
13.	PACKING RINGS (16 mm. S.Q. RING)	ASBESTOS—GRAPHITE	6	NOTE 5

1. THIS DRAWING IS NOT TO SCALE
2. LONGITUDINAL SEAMS HAVE TO BE COMPLETE JOINT PENETRATION WELDS BY COMBINING SINGLE-V-GROOVE WITH BACKING WELDS AND GROUND FLUSH WELDING WITH BASE METAL AS REQUIRED (SEE DETAIL "2")
3. GALVANIZED ALL SURFACES WITH 0.10 mm. THK.
4. NICKEL CLADDING ON OUTER SURFACE WITH 0.50 mm. THK. AND GALVANIZED INNER SURFACE WITH 0.10 mm. THK.
5. EACH JOINT OF EACH PACKING RING SHALL BE MIN. 25 cm. APART DO NOT LINE UP JOINTS
6. ALL DIMENSIONS ARE IN MILLIMETER UNLESS OTHERWISE SHOWN
7. THIS DRAWING IS ONLY A GUIDELINE. THE CONSTRUCTION SHOP DRAWING SHALL BE DESIGNED BY CONTRACTOR AND APPROVED BY DEDP'S ENGINEER

CP = COMPLETE JOINT PENETRATION GROOVE WELD

G = GRINDING WELD DEPOSIT FLUSH WITH BASE METAL

• = BACKING PLATE SIZE 0.10x1.50 mm. AND SAME MATERIAL AS PENSTOCK

● = BEVEL PLATE 9 mm. BEFORE ROLLING CHIP SQUARE AFTER WELDING

▲ = ROOT OPENING R = 2.0 mm.


ROOT FACE t = 3.0 mm.


GROOVE ANGLE = 45°

■ = ROOT OPENING R = 2.0 mm.

ROOT FACE t = 2.0 mm.

GROOVE ANGLE = 60°

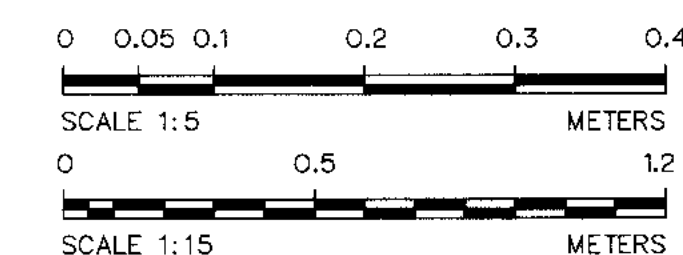


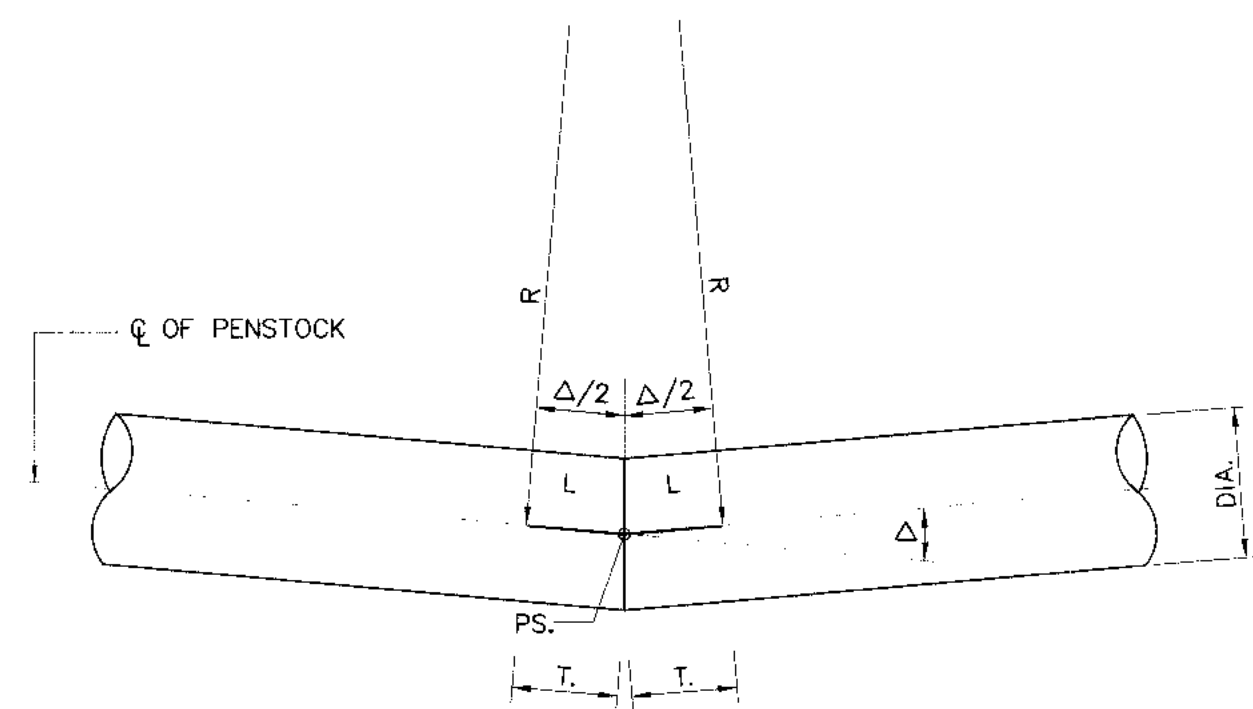

BEND TYPE "1"

DELTA(Δ) 0°-5°


SCALE 1:20

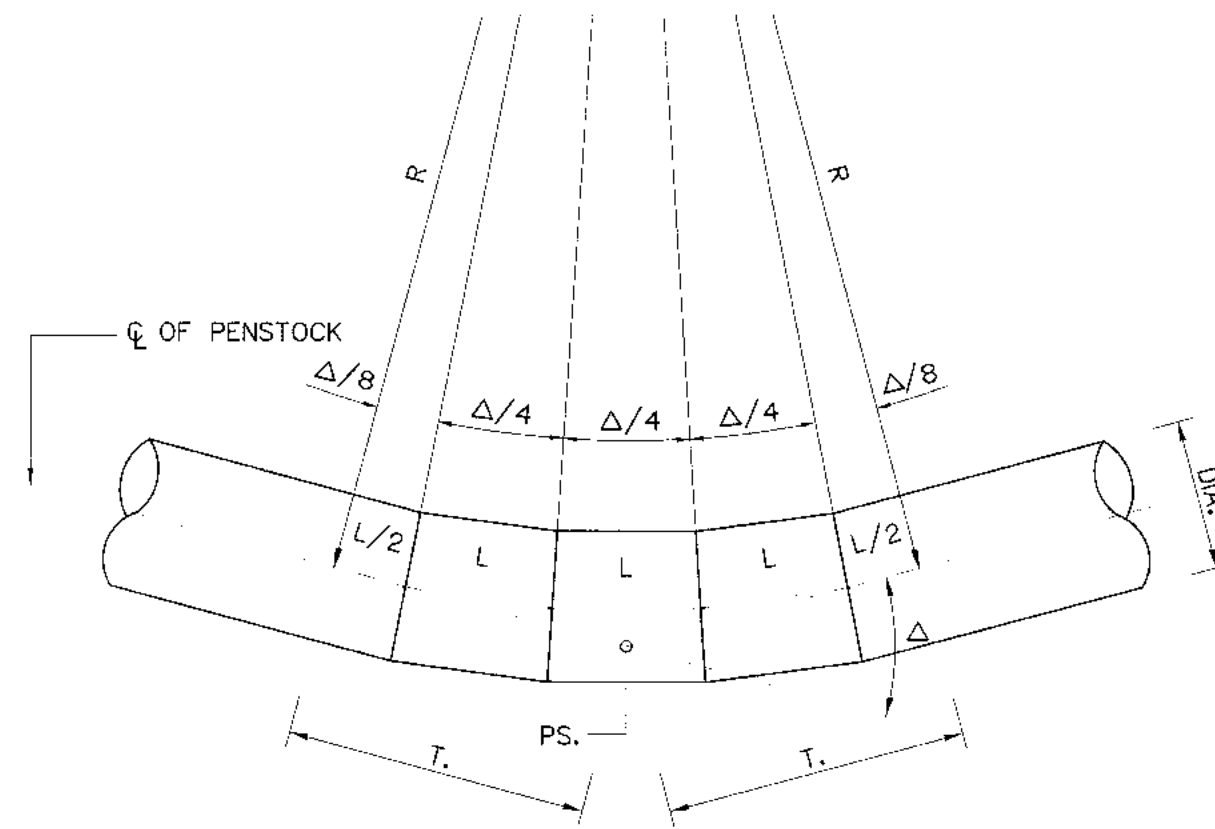

BEND TYPE "4"

DELTA(Δ) 25°-35°


SCALE 1:20

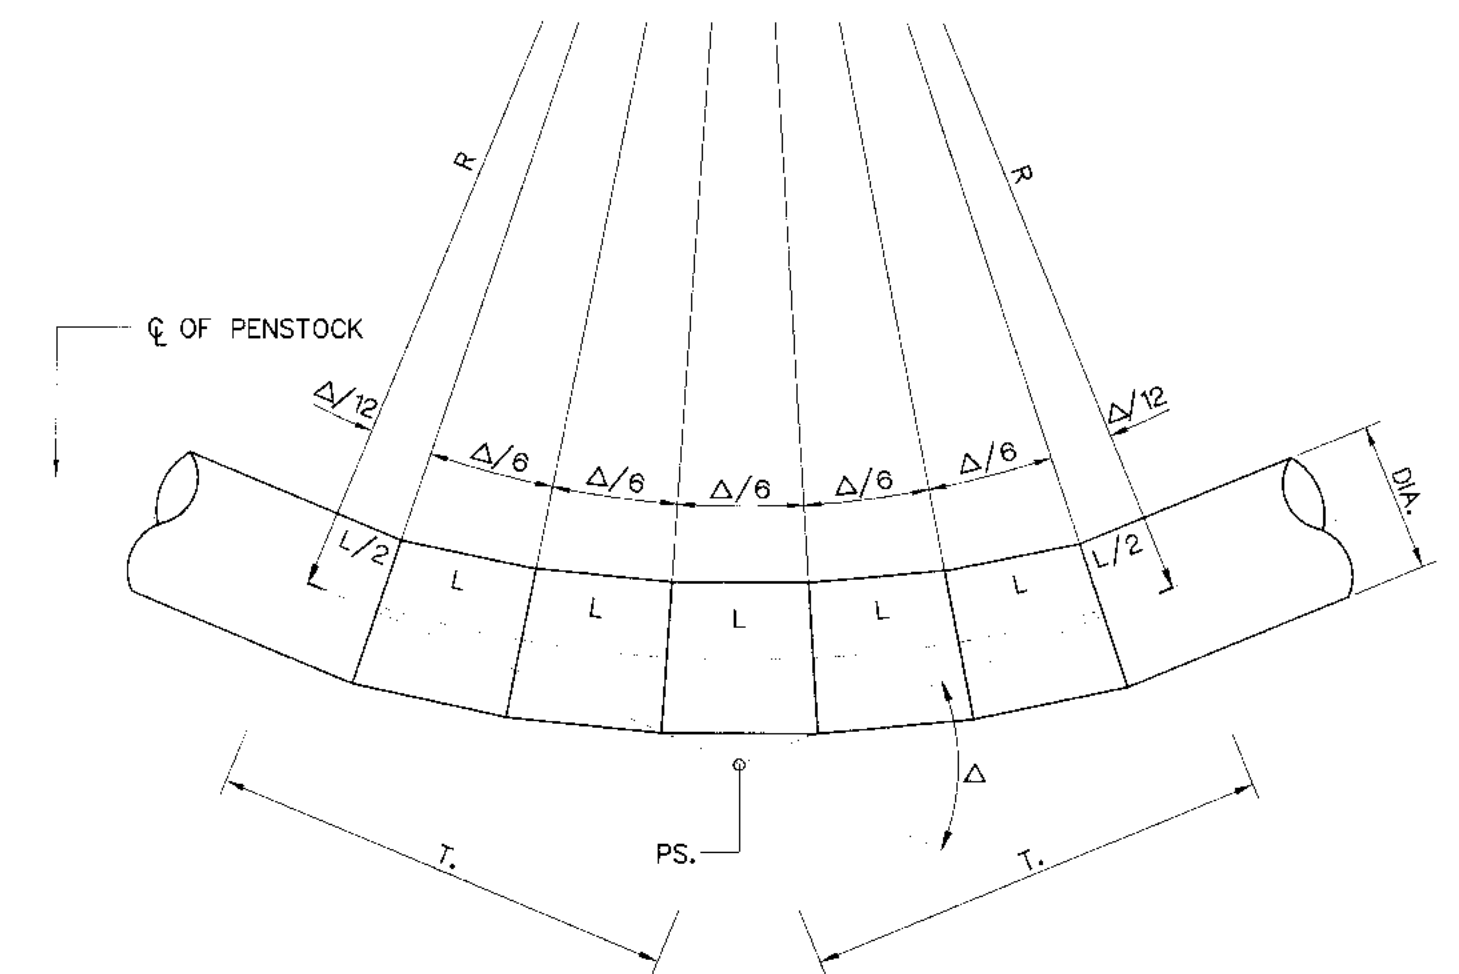

BEND TYPE "6"

DELTA(Δ) 55°-OVER


SCALE 1:20

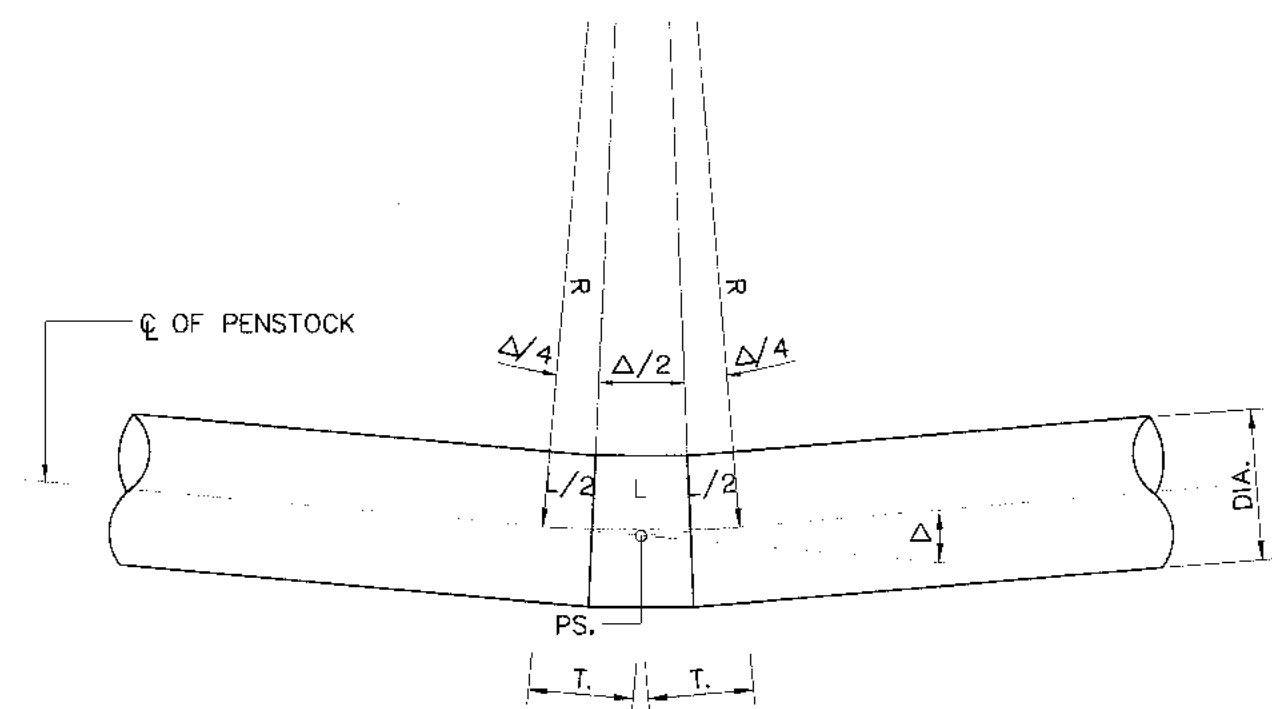

BEND TYPE "2"

DELTA(Δ) 5°-15°


SCALE 1:20

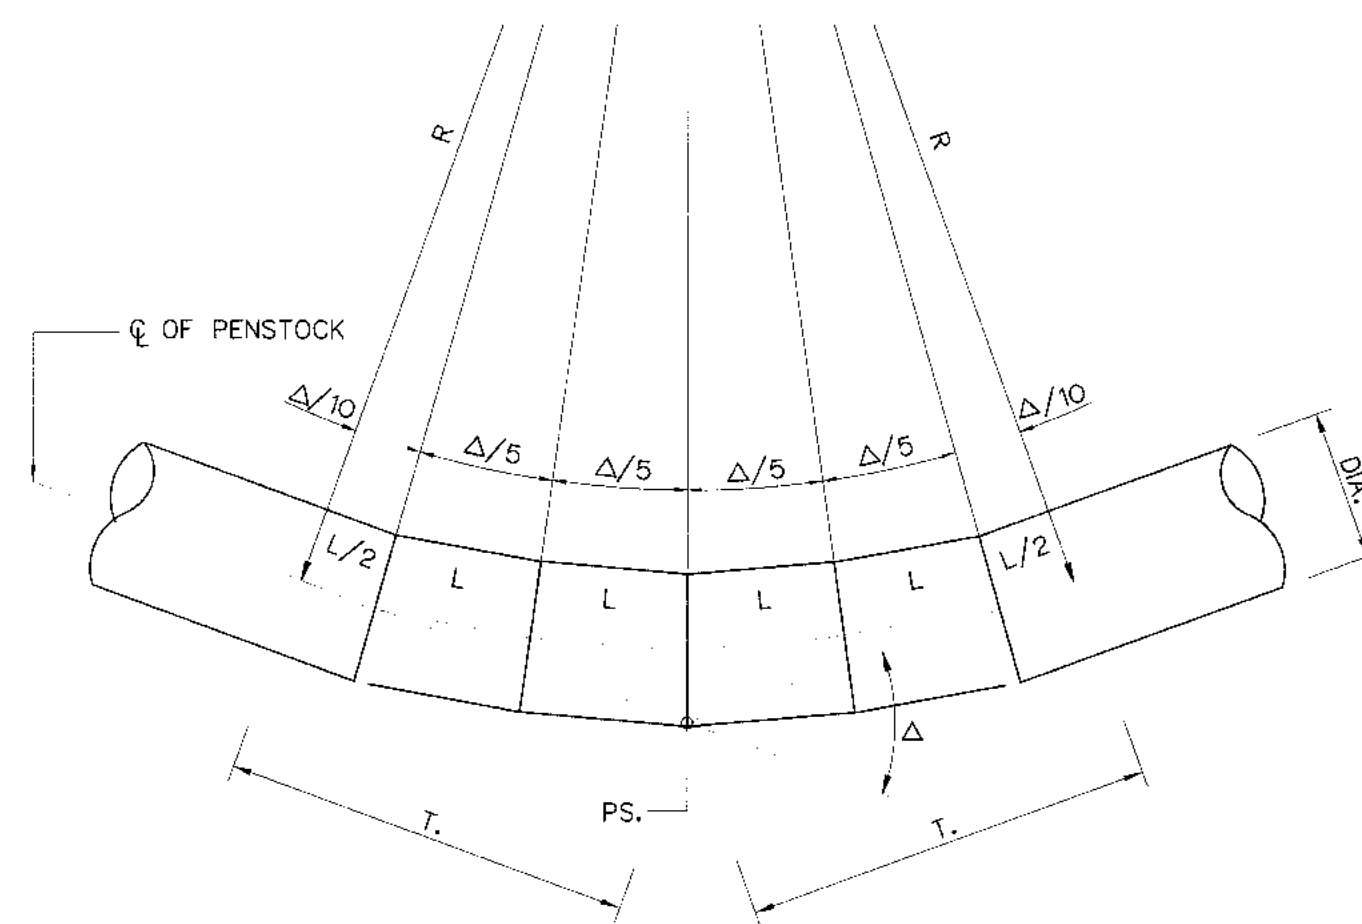

BEND TYPE "5"

DELTA(Δ) 35°-45°

SCALE 1:20

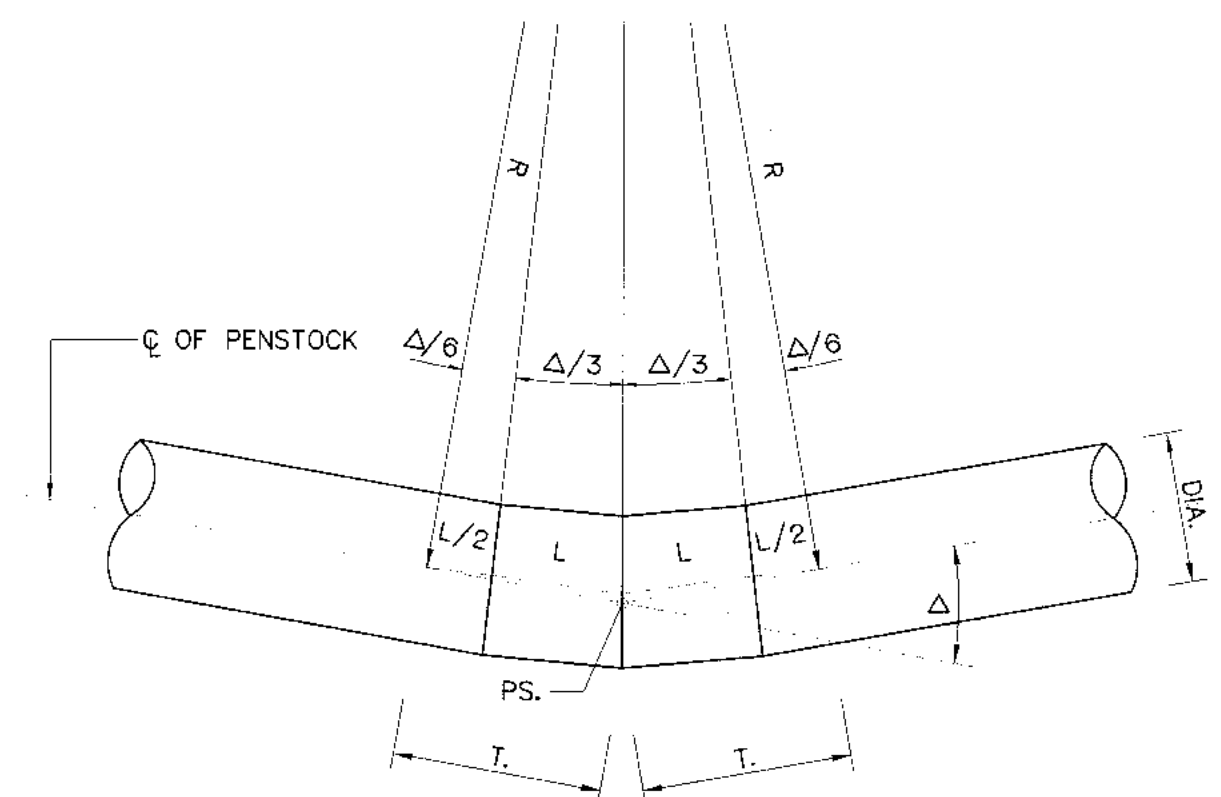

BEND TYPE "3"


DELTA(Δ) 15°-25°

SCALE 1:20

D	TEE		ELBOW							
			2-PIECE $\theta = 11.25^\circ$		3-PIECE $\theta = 22.25^\circ$		4-PIECE $\theta = 45^\circ$		5-PIECE $\theta = 45^\circ$	
	Run J+J	Outlet J	M	a	N	b	P	c	Q	d
150	800	400	100	250	175	225	275	225	375	250
200	850	425	100	250	200	225	300	225	450	250
250	900	450	100	250	225	200	350	225	500	250
300	1400	700	125	275	250	275	400	275	575	300
400	1600	800	150	350	300	325	500	325	700	350
500	1750	875	175	350	350	325	550	325	825	350
600	2000	1000	200	350	400	350	650	350	650	350
700	2250	1125	225	400	450	400	725	400	950	375
800	2500	1250	225	475	500	450	800	450	1075	425
900	2600	1300	250	450	525	450	850	425	1175	475
1,000	2850	1425	250	525	550	500	875	500	1250	450
1,200	2850	1425	275	400	575	400	950	375	1300	525
1,500	3400	1700	300	475	675	475	1050	450	1375	400
1,800	3800	1900	325	450	700	425	1150	425	1575	550

NOTE :




1. SYMBOLS, ABBREVIATIONS AND GENERAL NOTES SEE DWG. NO. KLP-GN-03

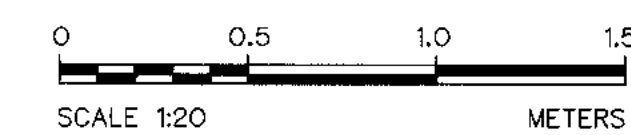

3				
2				
1				
NO.	DATE	REVISIONS	CHECKED	APPROVED

CONSULTANTS DEDE

KINGDOM OF THAILAND Department of Alternative Energy Development and Efficiency MINISTRY OF ENERGY	
KLONG LAM PLOK HYDROPOWER PROJECT	
CIVIL WORKS AND TRANSMISSION LINE PENSTOCK BEND DETAILS	
P&C MANAGEMENT CO.,LTD. DESIGNED <i>[Signature]</i> 201.29074 201.6226 DRAWN <i>[Signature]</i> CHECKED <i>[Signature]</i> 201.6226	REVIEWED <i>[Signature]</i> SUBMITTED <i>[Signature]</i> RECOMMENDED <i>[Signature]</i> APPROVED <i>[Signature]</i>
PROJECT MANAGER DATE 08/03/2559	DRAWING NO. KLP-PS-12 SHEET NO. 70 OF 110

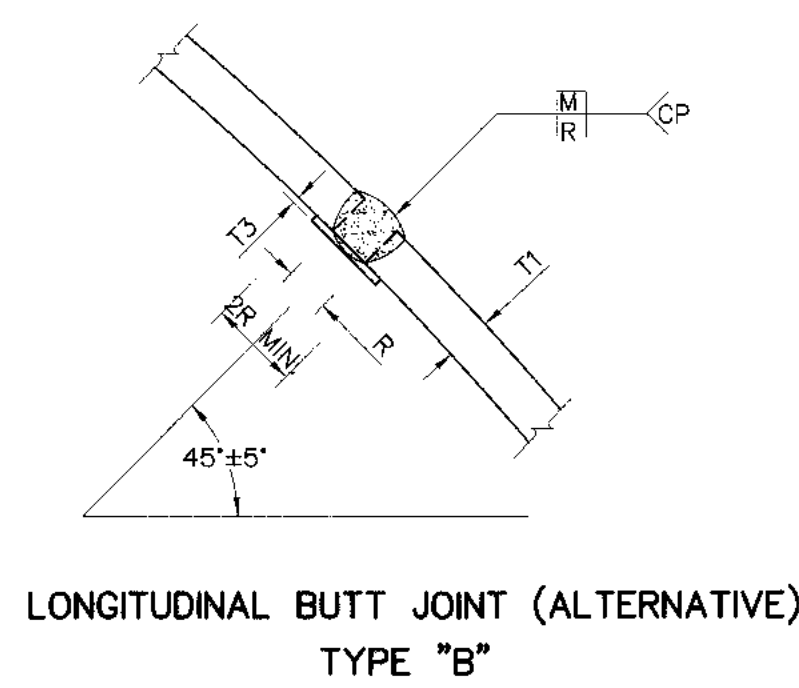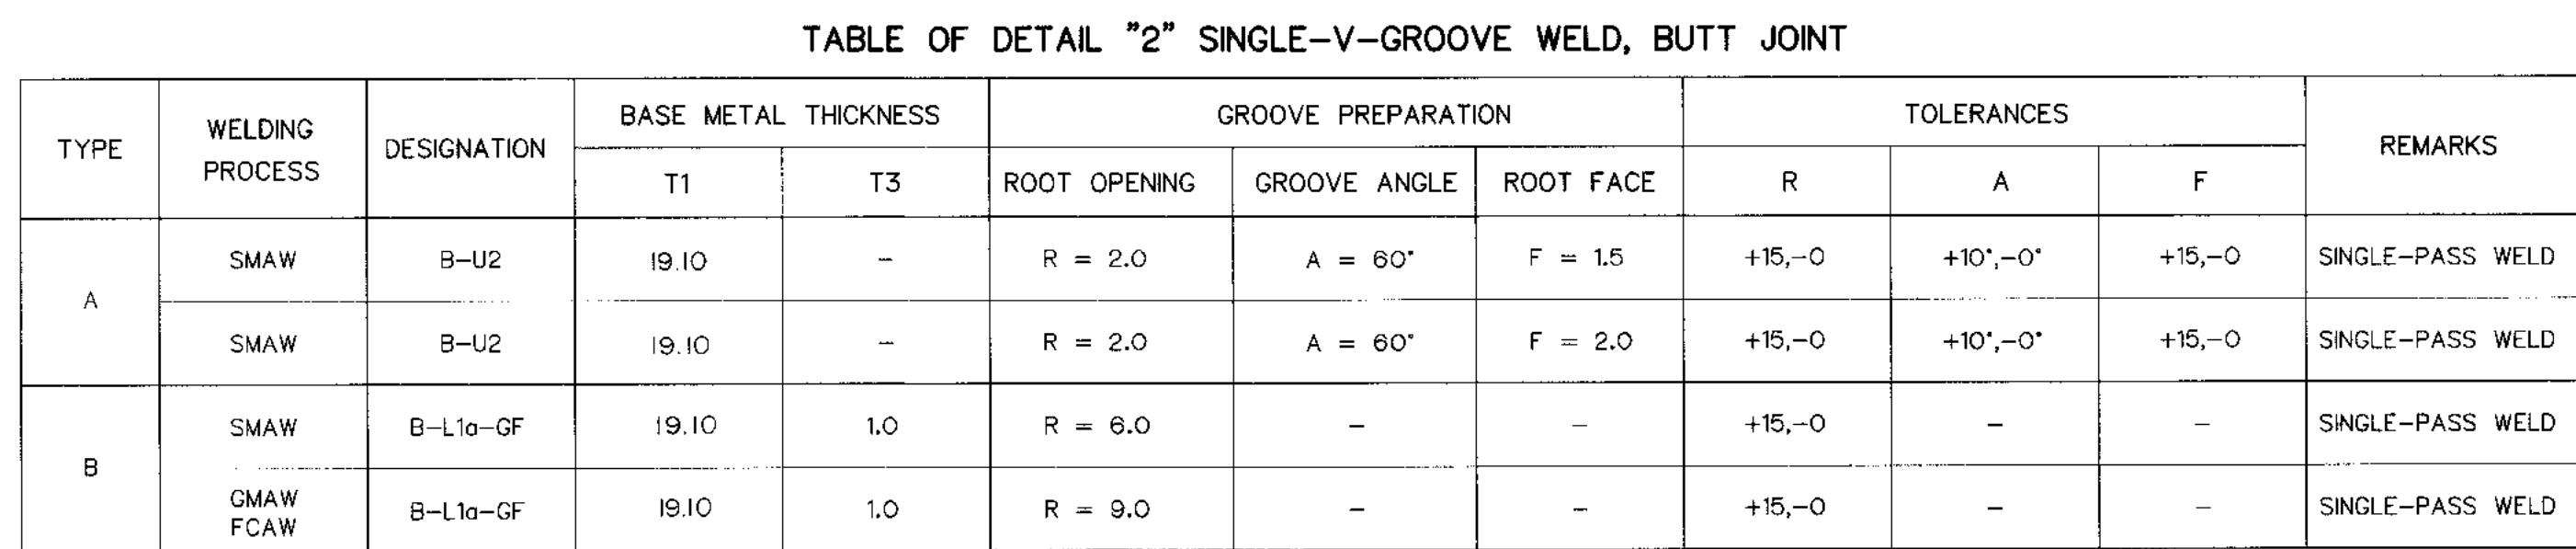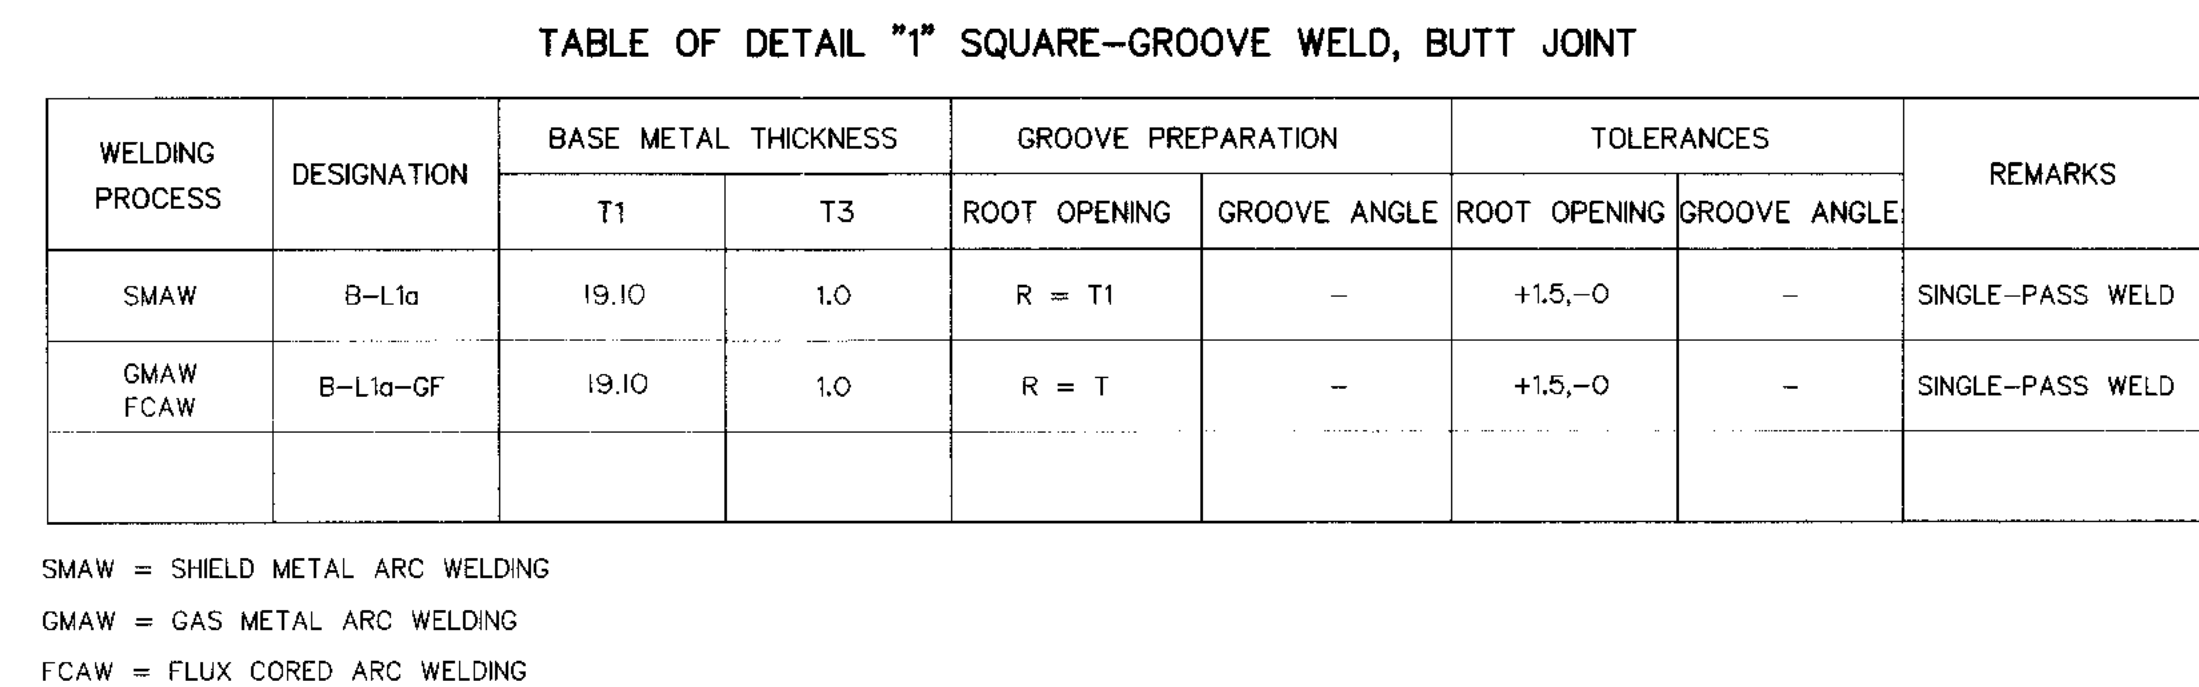





WELDING SYMBOLS										
										
FIELDWELD SYMBOL	WELD - ALL - AROUND SYMBOL	SQUARE GROOVE WELDING SYMBOL R=ROOT OPENING	V-GROOVE WELDING SYMBOL R=ROOT OPENING A=GROOVE ANGLE F=ROOT FACE	BACKING SYMBOL (MATERIAL OF BACKING THE SAME AS OF PIPE)	COMPLETE JOINT PENETRATION WELD	FILLET WELD S=WELDING SIZE L=LENGTH OF WELD P=PITCH (CENTER TO CENTER OF WELD)	BACK OR BACKING WELD SYMBOL	COMBINED WELDS. BACKING WELD ON FAR SIDE AND V-GROOVE WELD ON NEAR SIDE	BEVEL GROOVE WELDING SYMBOL	FLARE-BEVEL GROOVE WELDING SYMBOL

NOTES :

1. ALL DIMENSION ARE IN MILLIMETER, UNLESS OTHERWISE SHOWN.
2. SYMBOLS, ABBREVIATIONS AND GENERAL NOTES SEE DWG. NO. KLP-GN-03
3. GROOVE WELD MADE AFTER WELDING OTHER SIDE
4. USE WELDING ELECTRODE TYPE "E" 70
5. MATERIAL OF BACKING IS THE SAME AS OF PIPE
6. THIS DRAWING IS ONLY GUIDELINE THE CONSTRUCTION SHOP DRAWING SHALL BE DESIGNED BY CONTRACTOR AND APPROVED BY DEEDP'S ENGINEER



 KINGDOM OF THAILAND Department of Alternative Energy Development and Efficiency MINISTRY OF ENERGY				
KLONG LAM PLOK HYDROPOWER PROJECT				
CIVIL WORKS AND TRANSMISSION LINE				
PENSTOCK				
WELDING DETAILS				
 P&C MANAGEMENT CO.,LTD.		 Department of Alternative Energy Development and Efficiency MINISTRY OF ENERGY		
3				DESIGNED <i>[Signature]</i> 18/12/9074 <i>[Signature]</i> 25/12/20
2				DRAWN <i>[Signature]</i>
1				CHECKED <i>[Signature]</i> 25/12/20
NO.	DATE	REVISIONS	CHECKED	APPROVED
CONSULTANTS		DEDE		

DESIGNED <i>[Signature]</i> 18/12/9074 <i>[Signature]</i> 25/12/20 DRAWN <i>[Signature]</i> CHECKED <i>[Signature]</i> 25/12/20		REVIEWED <i>[Signature]</i> SUBMITTED <i>[Signature]</i> RECOMMENDED <i>[Signature]</i> APPROVED <i>[Signature]</i>	
PROJECT MANAGER <i>[Signature]</i> 08/03/2559 DATE		DRAWING NO. KLP-PS-13	
		SHEET NO. 71 OF 110	

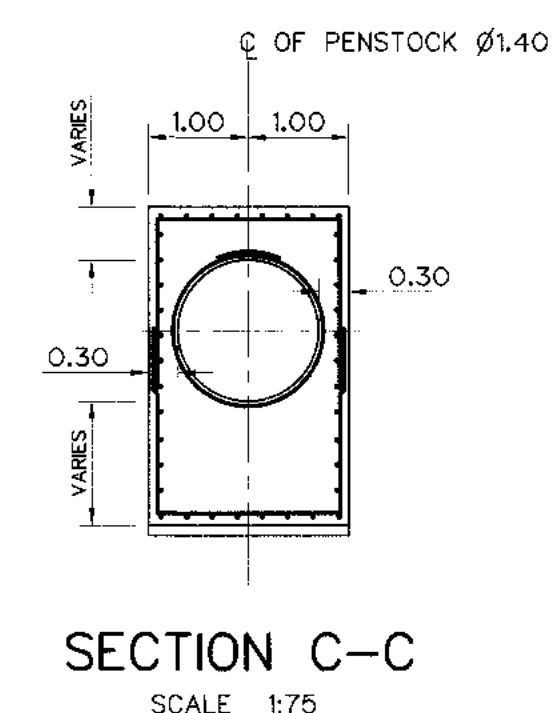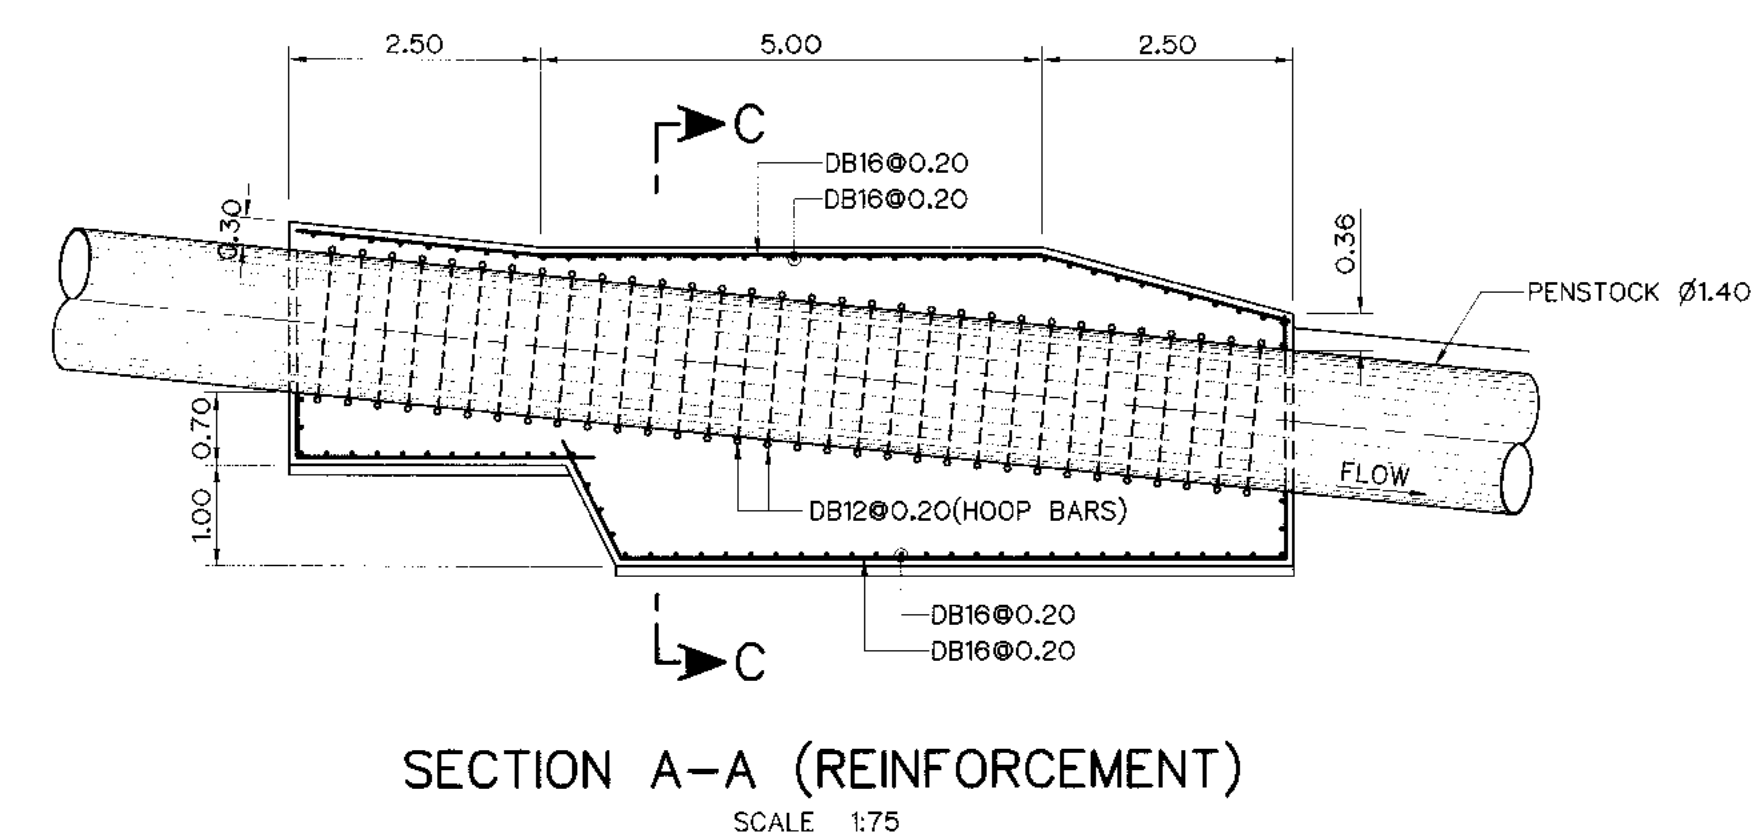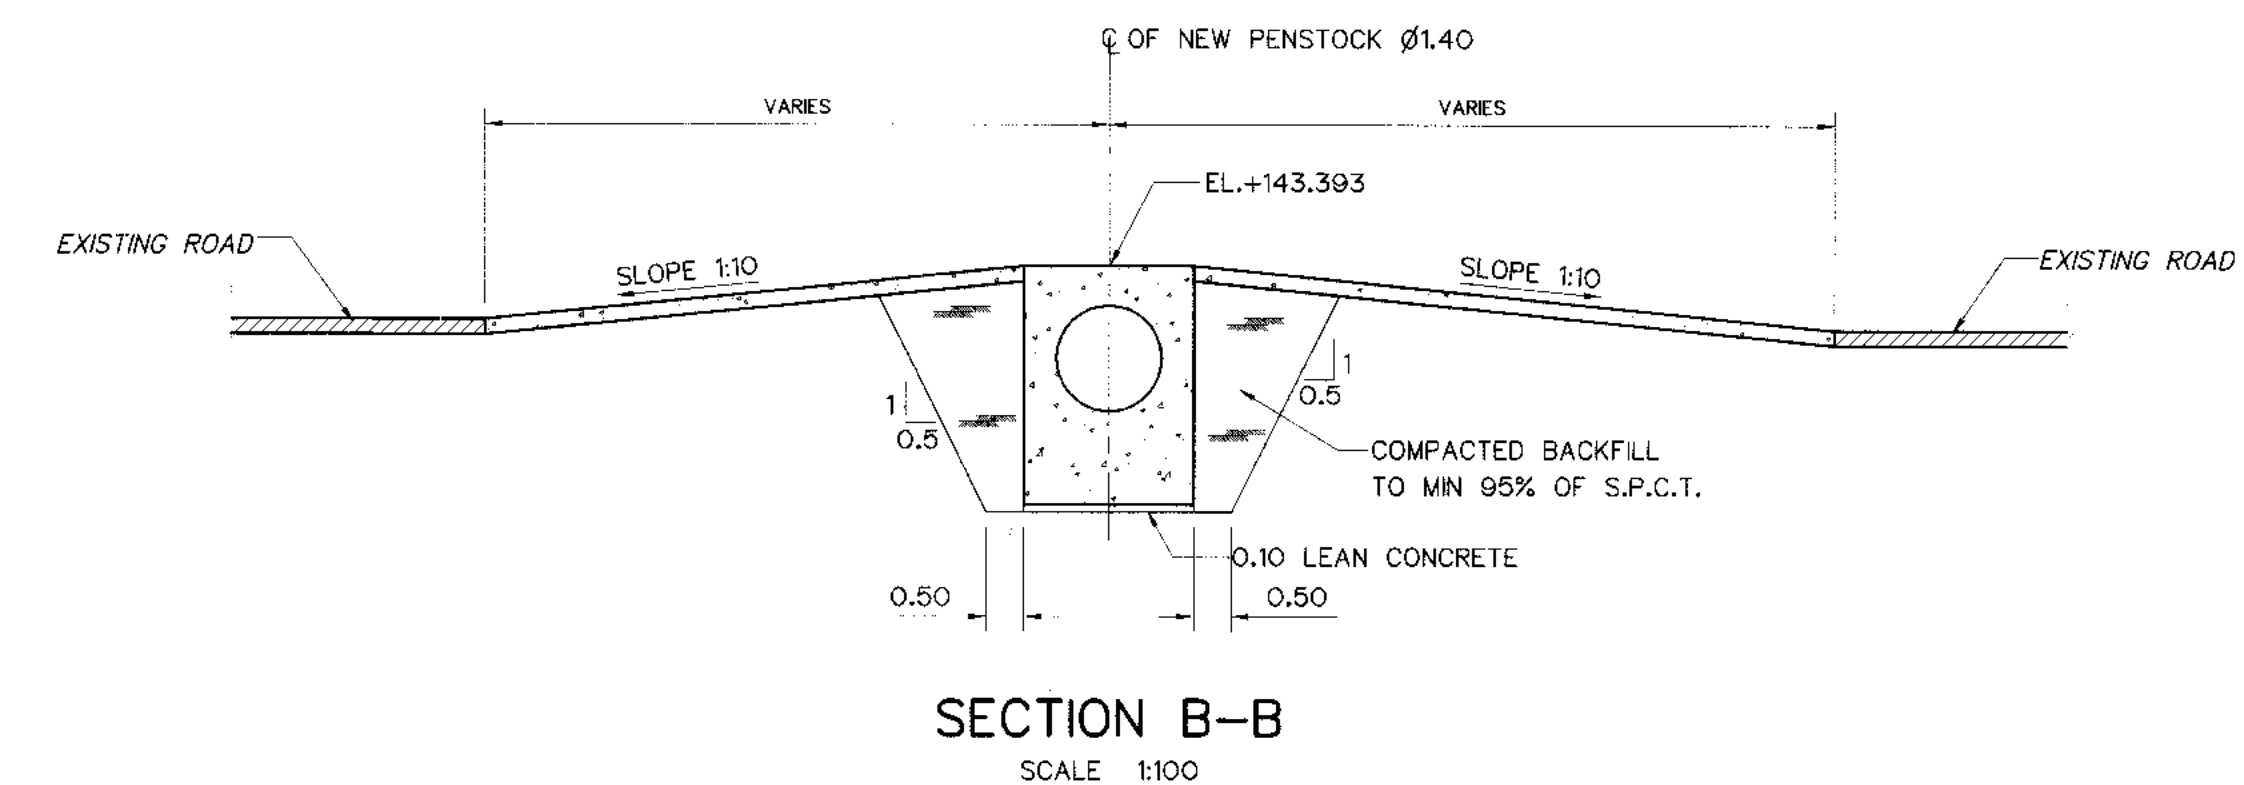
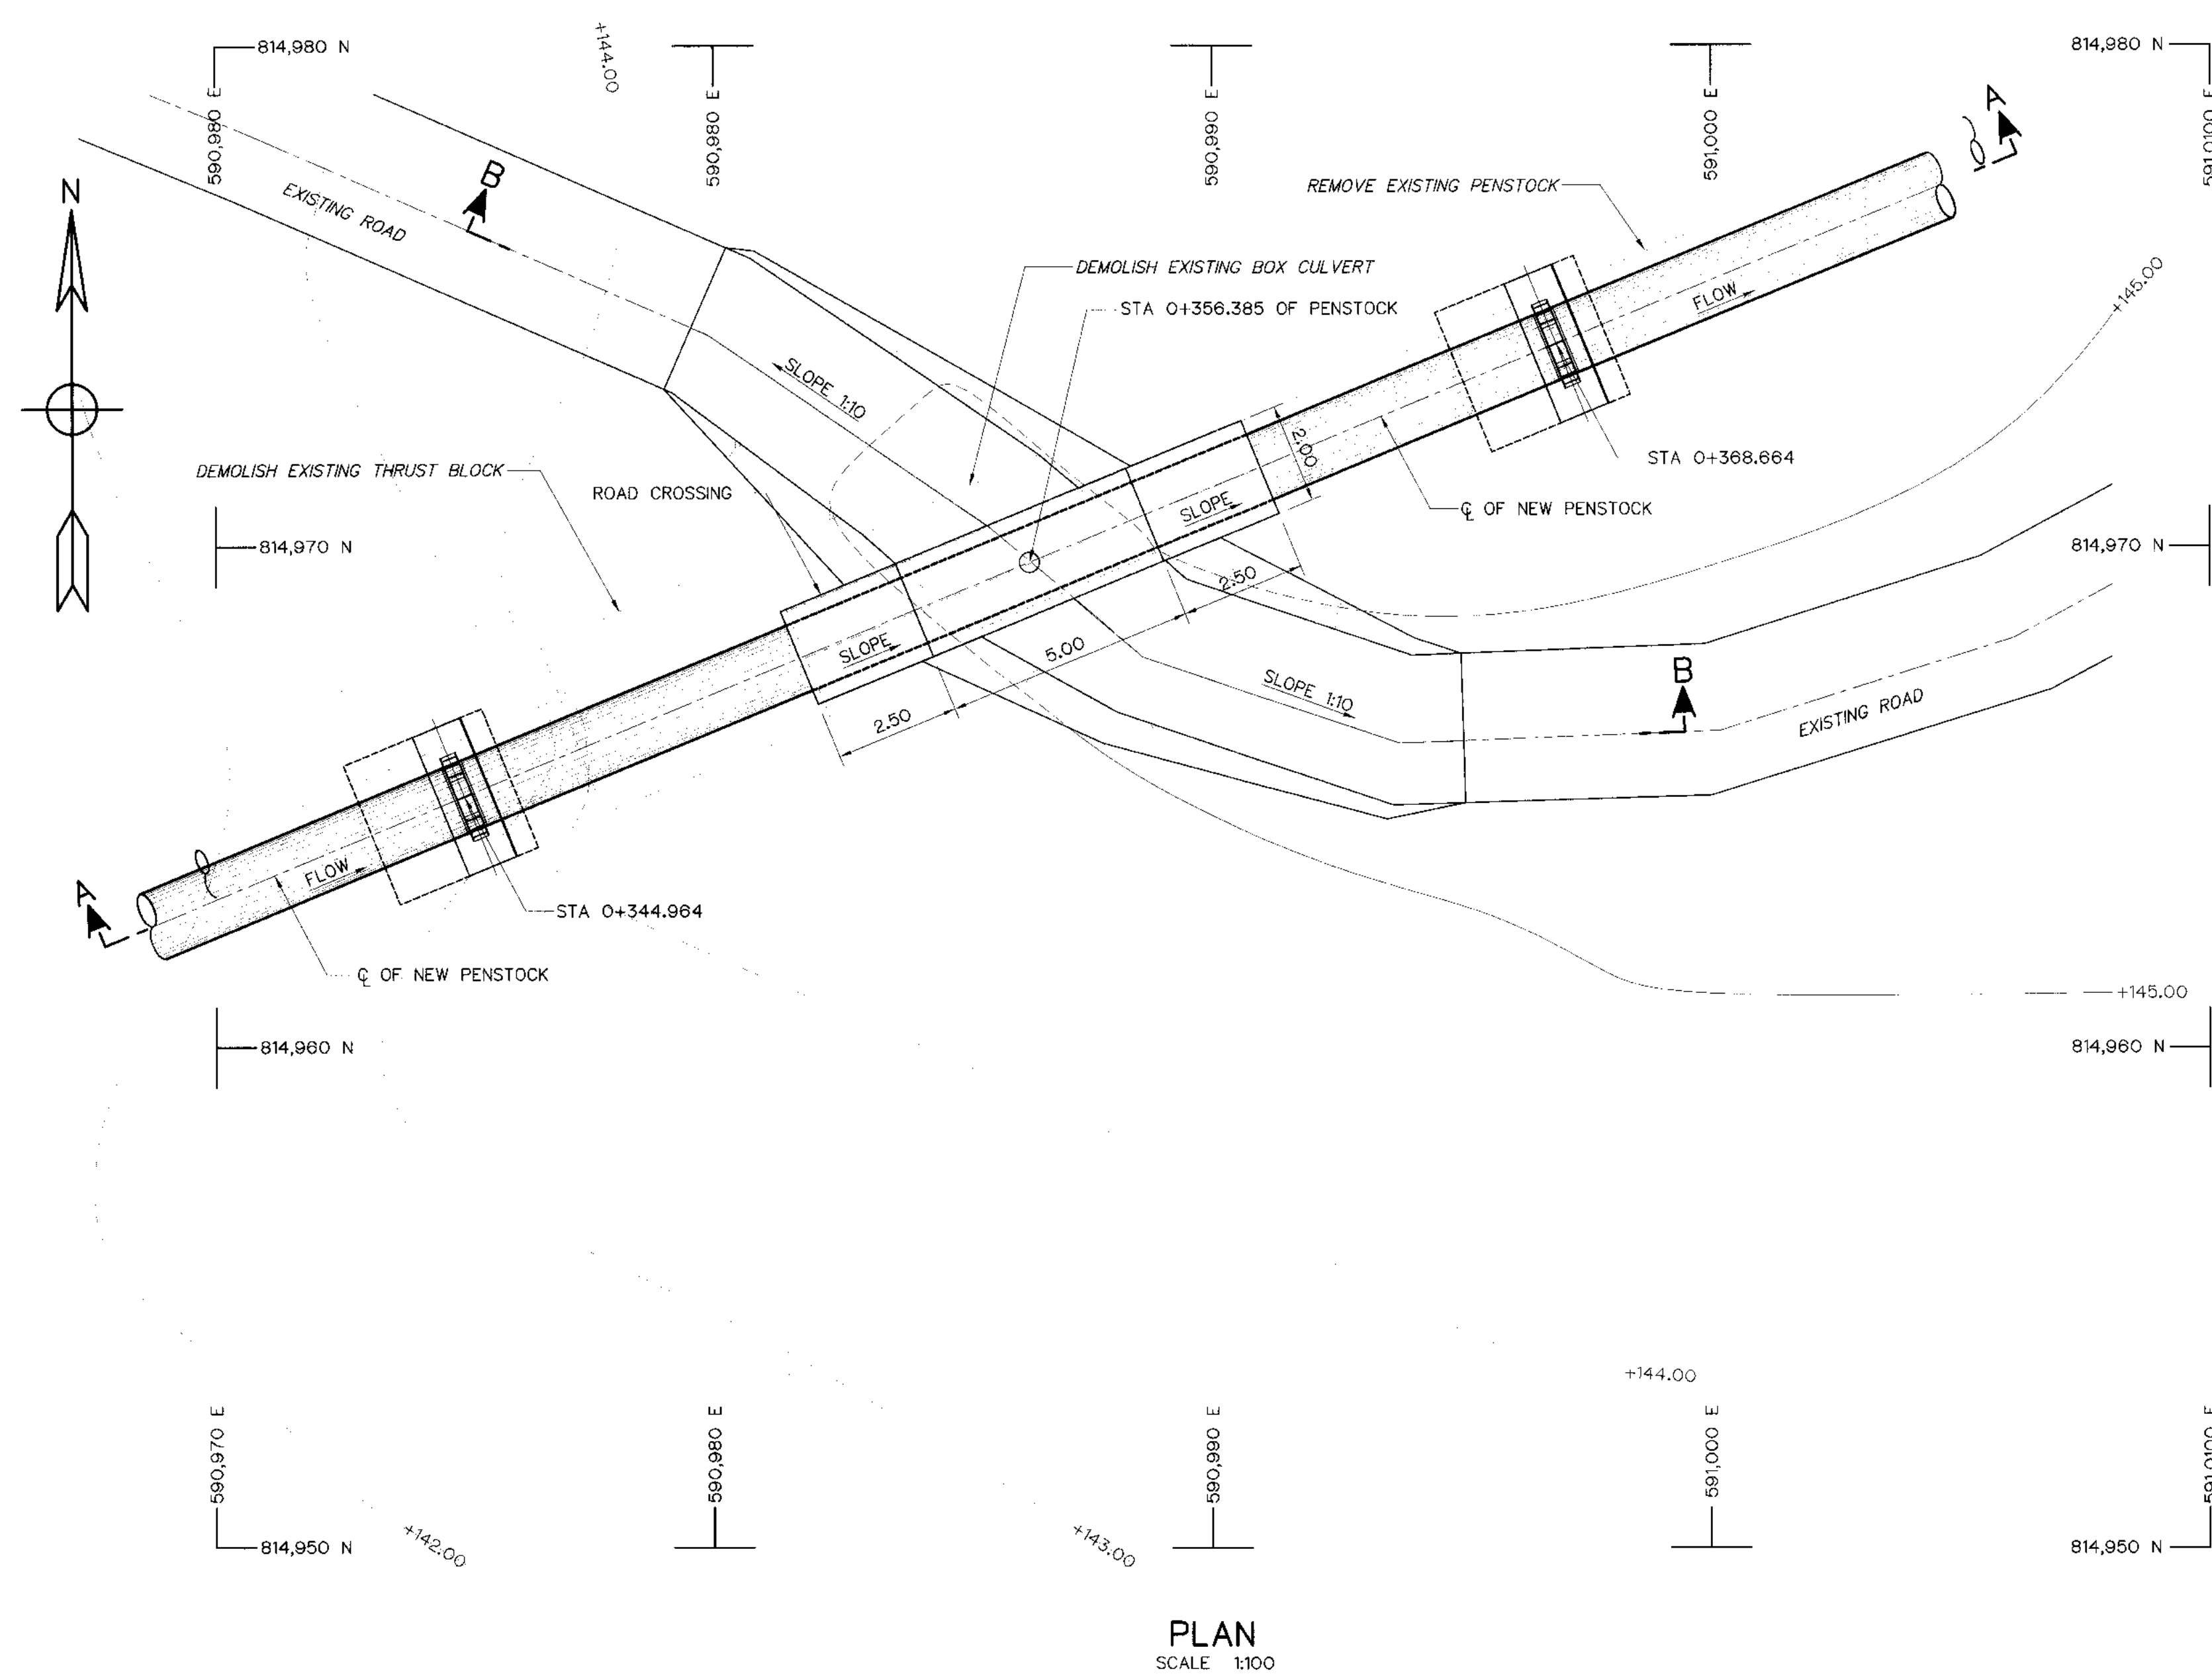


- NOTES :**
1. ALL DIMENSIONS AND ELEVATIONS (M.S.L.) ARE IN METERS. UNLESS OTHERWISE SHOWN.
 2. SYMBOLS, ABBREVIATIONS AND GENERAL NOTES SEE DWG. NO. KLP-GN-03
 3. THE ALIGNMENT OF THE HEADRACE AND RELATED STRUCTURES SHALL BE CHECK AND CORRECTED BY THE CONTRACTOR TO SUIT THE FIELD CONDITIONS AND SHALL BE SUBMITTED TO DEDE'S FIELD ENGINEER FOR APPROVAL

- REFERENCE DRAWINGS :
- | | |
|--|-----------|
| 1. PENSTOCK PLAN AND PROFILE, STA. 0+000 TO STA. 0+500 | KLP-PS-01 |
| 2. PENSTOCK PIPE SUPPORT SECTIONS AND DETAILS | KLP-PS-08 |

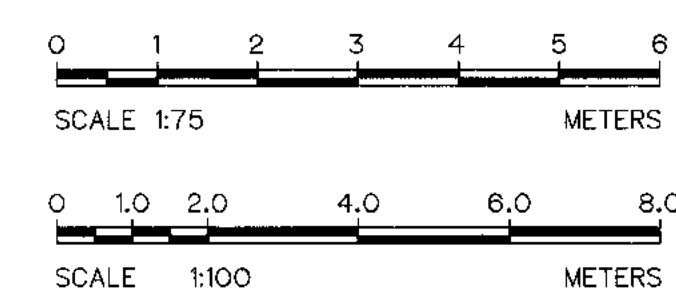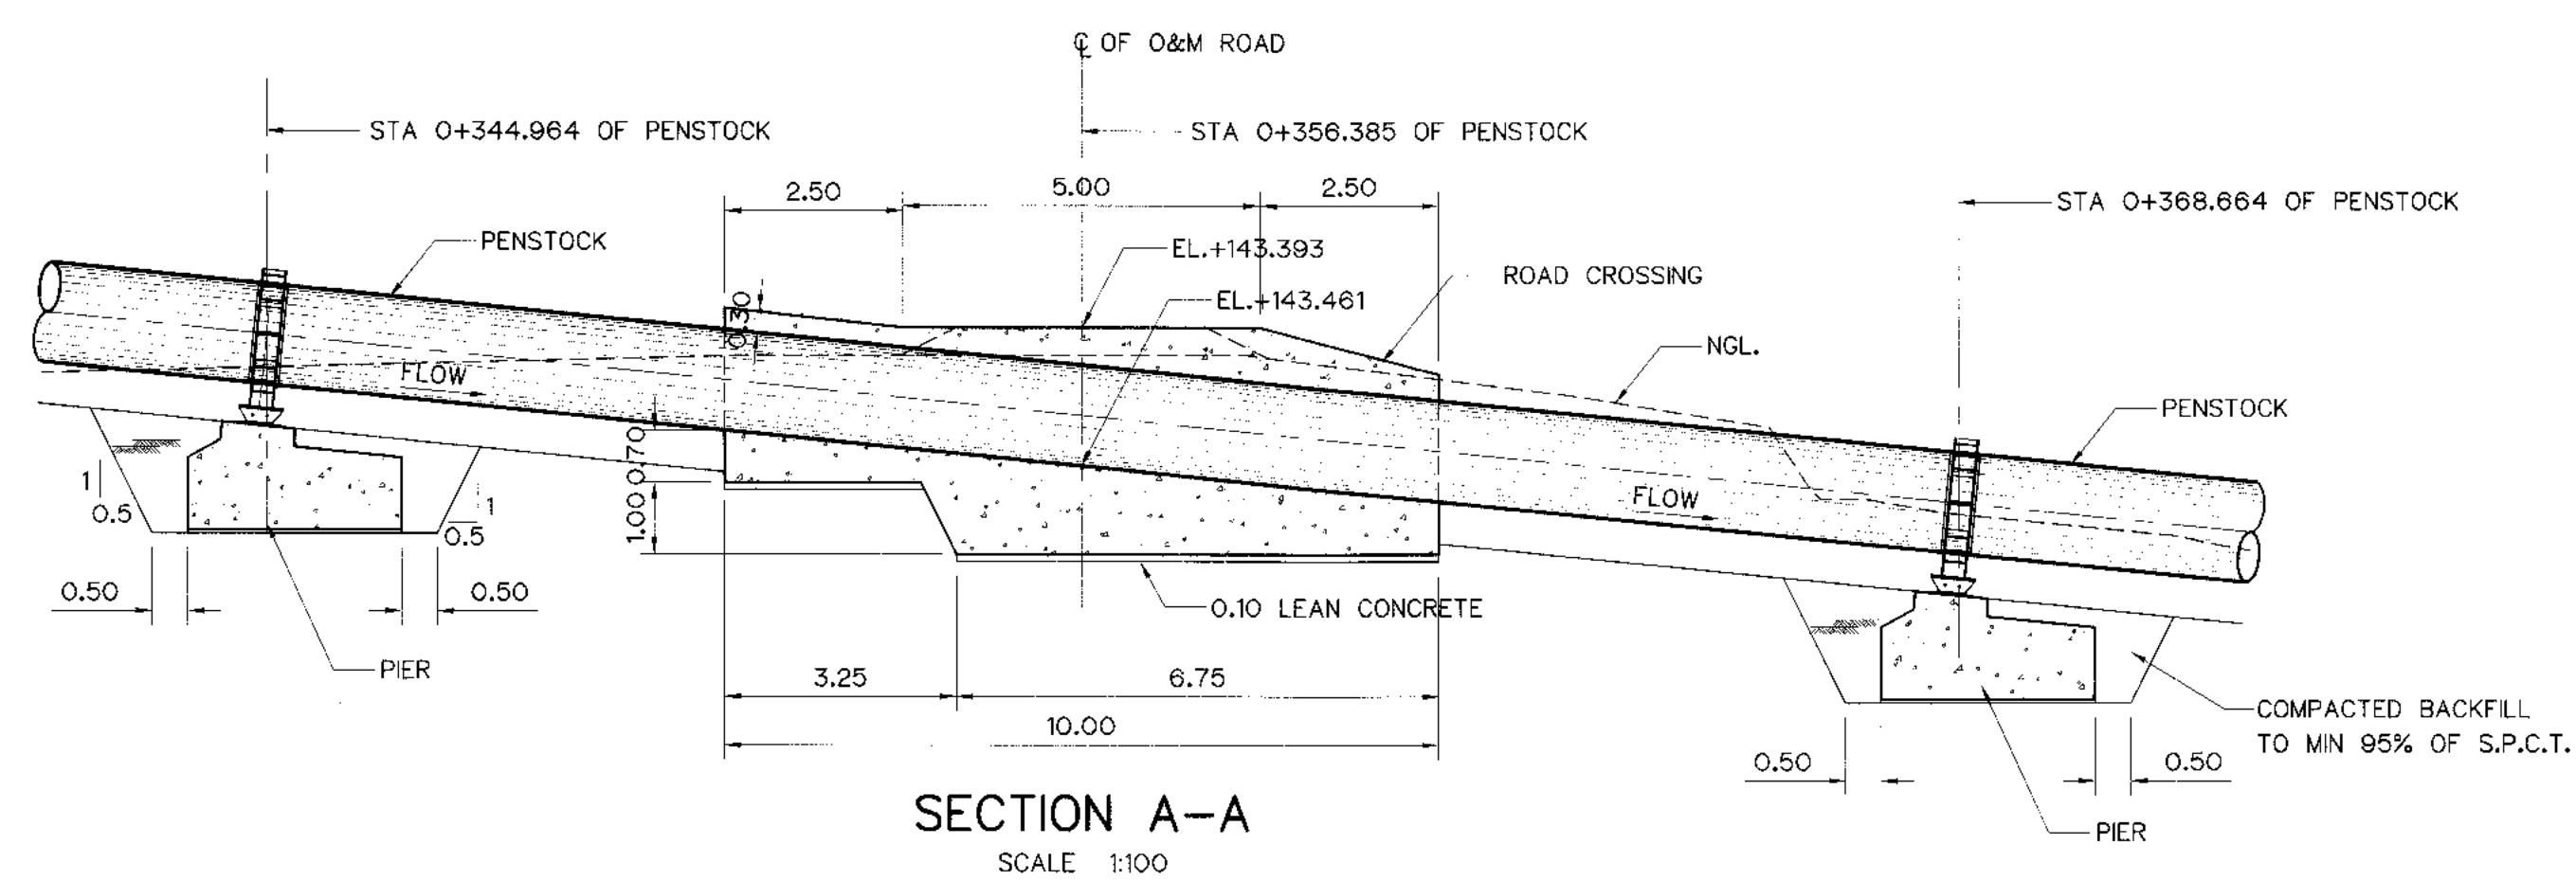

3					P&C MANAGEMENT CO., LTD.	REVIEWED	<i>[Signature]</i>
2					DESIGNED <i>H</i> 09.29074 <i>B.D.</i> 08.6226	SUBMITTED	<i>Chenot</i>
1					DRAWN <i>[Signature]</i>	RECOMMENDED	<i>[Signature]</i>
NO.	DATE	REVISIONS	CHECKED	APPROVED	CHECKED	APPROVED	
					<i>B.D.</i>	08.6226	<i>P. Hanyall</i>
CONSULTANTS					DEDE		
					PROJECT MANAGER	DATE	DRAWING NO. KLP-PS-14
						08/03/2559	SHEET NO. 72 OF 110

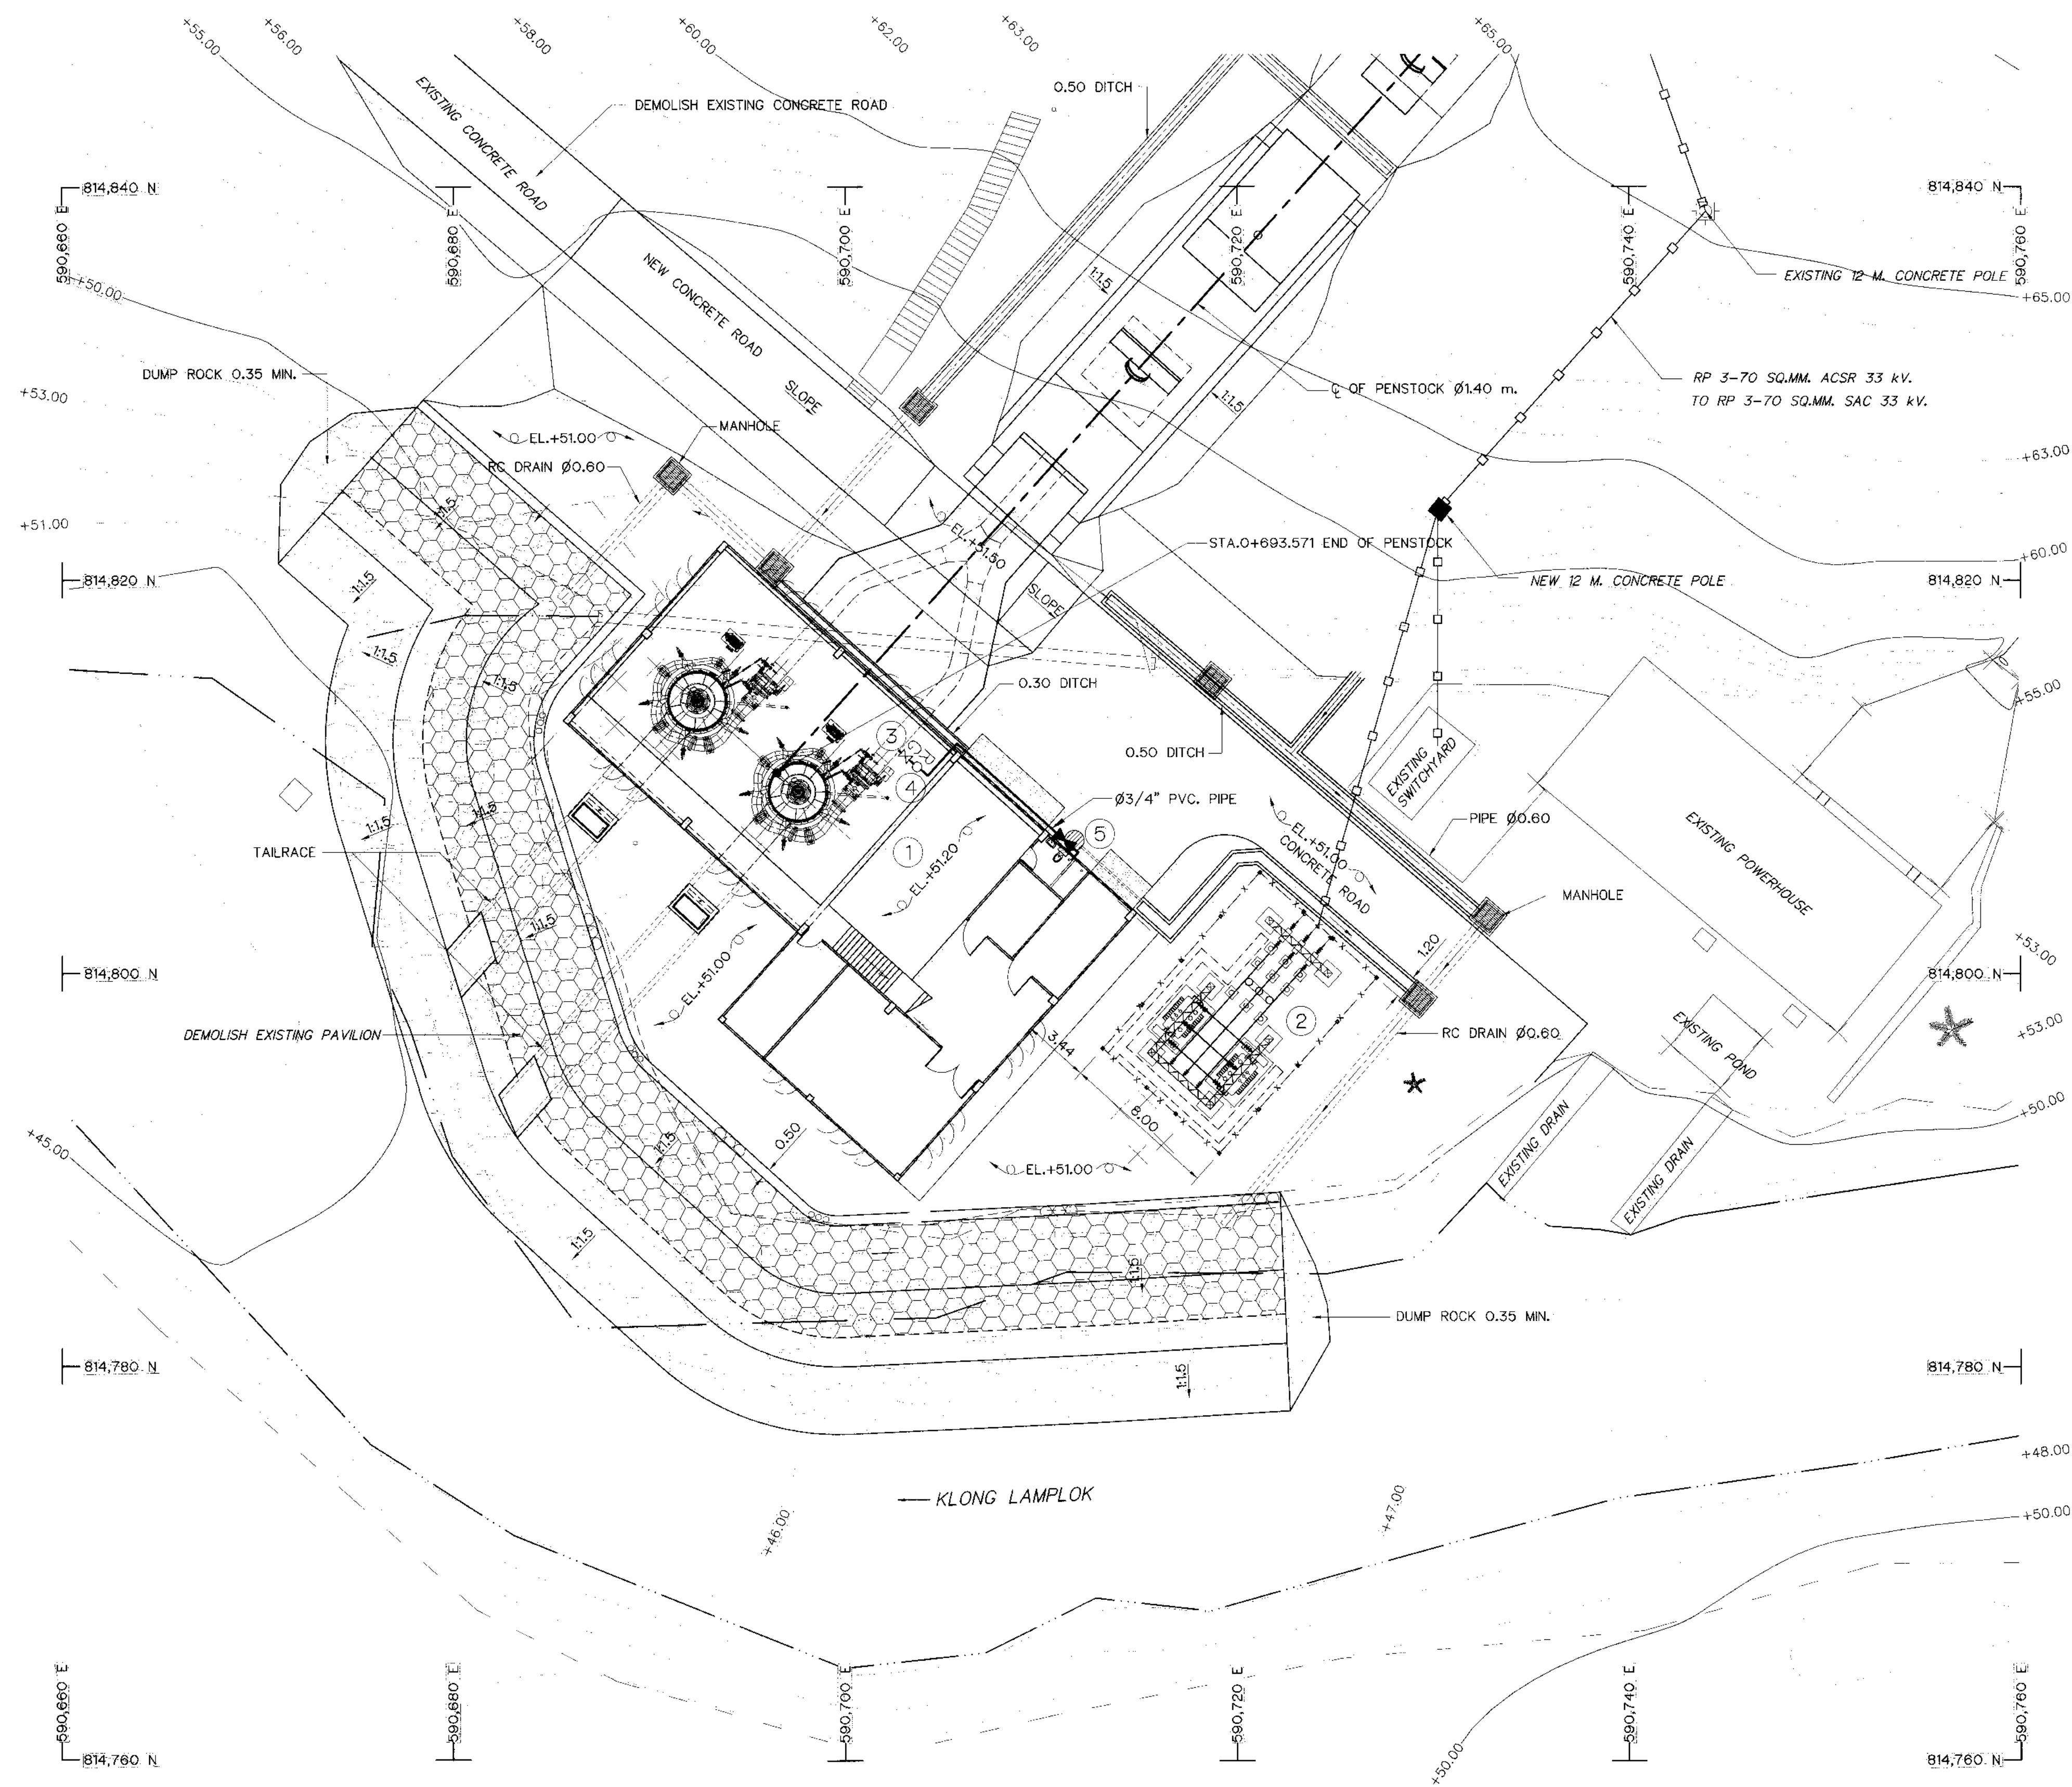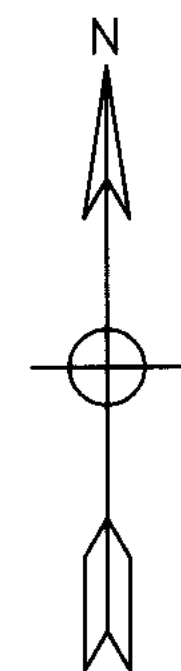

GENERAL LAY-OUT
SCALE 1:200

LISTS :


- 1 POWER HOUSE
- 2 SWITCHYARD
- 3 GATE VALVE Ø3/4"
- 4 PRESSURE REDUCING VALVE
- 5 SEPTICK TANK

NOTES :

1. ALL DIMENSIONS AND ELEVATIONS (M.S.L.) ARE IN METERS, UNLESS OTHERWISE SHOWN.
2. SYMBOLS, ABBREVIATIONS AND GENERAL NOTES SEE DWG. NO. KLP-GN-03


REFERENCE DRAWINGS :

- | | |
|--|-----------|
| 1. POWERHOUSE, PLAN 1st FLOOR | KLP-PH-02 |
| 2. POWERHOUSE, DITCH AND MANHOLE DETAILS | KLP-PH-18 |
| 3. TAILRACE, GENERAL LAY-OUT | KLP-TR-01 |

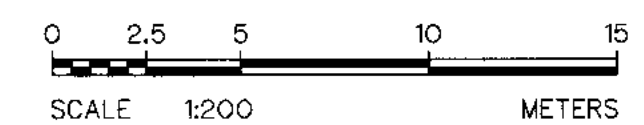

KINGDOM OF THAILAND Department of Alternative Energy Development and Efficiency MINISTRY OF ENERGY	
KLONG LAM PLOK HYDROPOWER PROJECT	
CIVIL WORKS AND TRANSMISSION LINE POWERHOUSE GENERAL LAY-OUT	
P&C MANAGEMENT CO.,LTD.	REVIEWED
DESIGNED <i>W</i> 08/29074 08/0228	SUBMITTED <i>Chart</i>
DRAWN <i>gmx</i>	RECOMMENDED
CHECKED <i>D.R.</i> 08/0228	APPROVED <i>P. Hannell</i>
PROJECT MANAGER	DRAWING NO. KLP-PH-01
DATE 08/03/2559	SHEET NO. 73 OF 110

3				
2				
1				
NO.	DATE	REVISIONS	CHECKED	APPROVED
CONSULTANTS		DEDE		

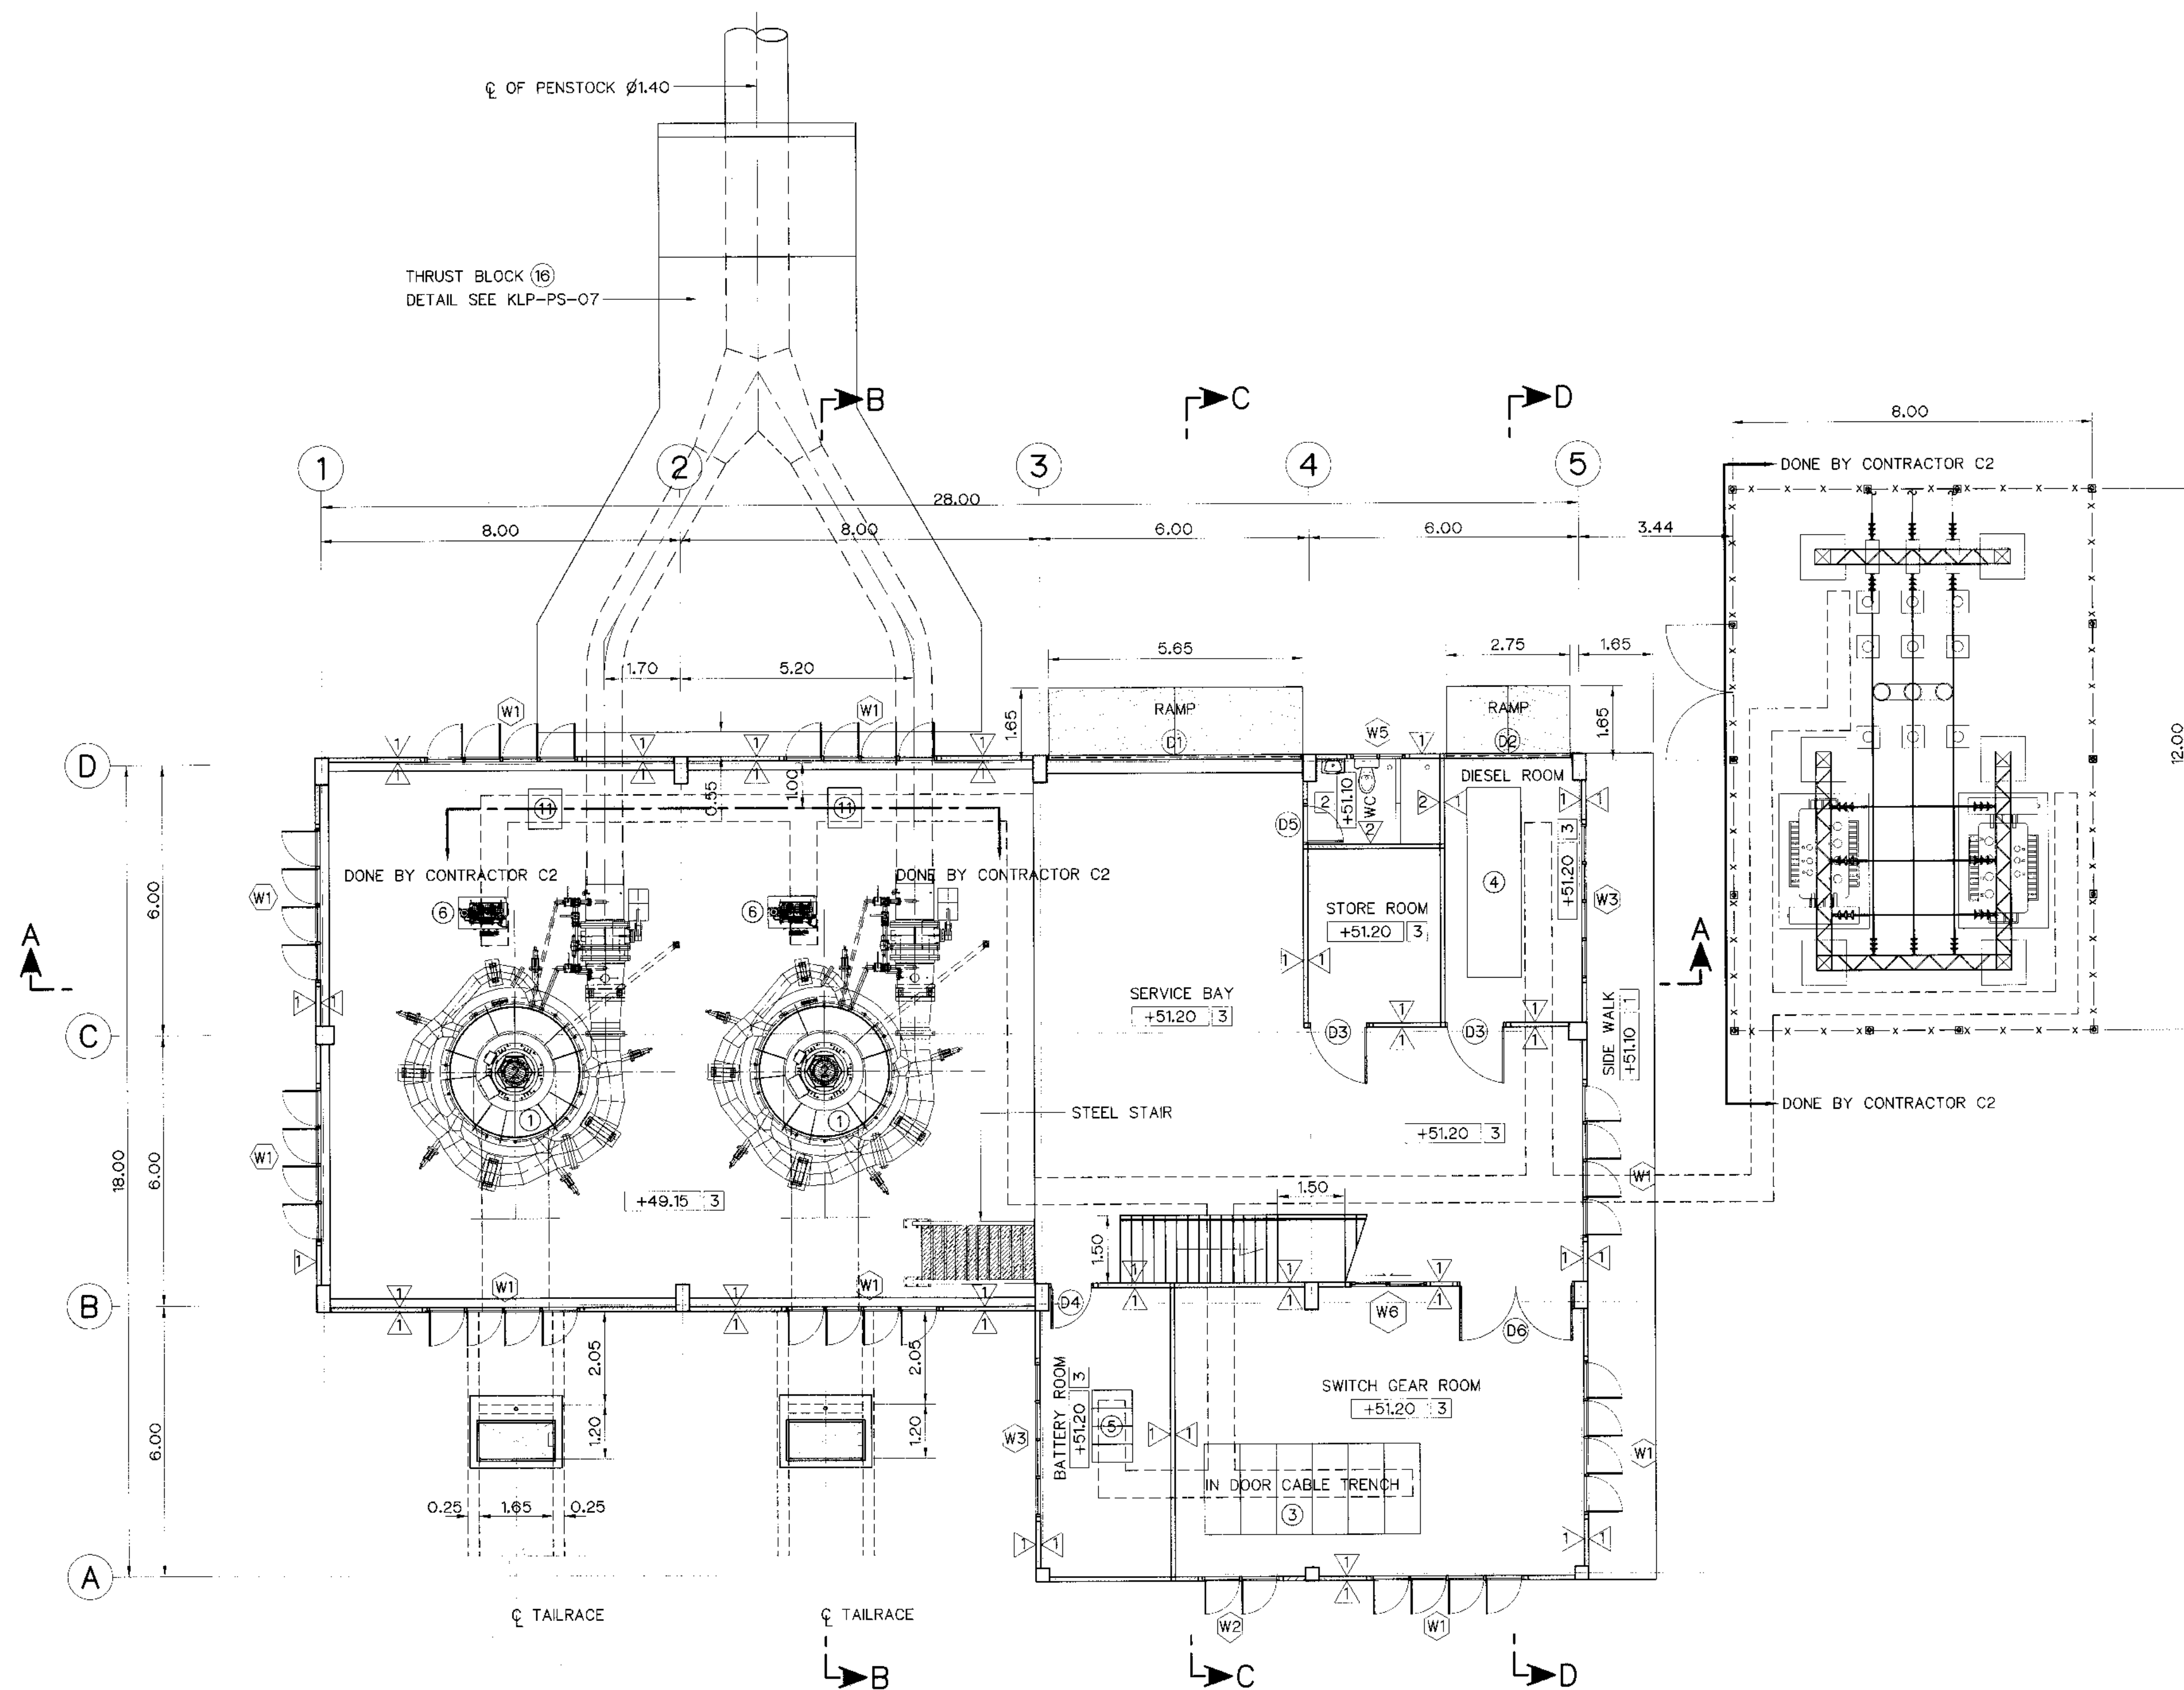

PLAN 1st FLOOR
SCALE 1:100



DESCRIPTIONS :

- ① VERTICAL SHAFT KAPLAN TURBINE
- ② GENERATOR
- ③ SWITCH GEAR CUBICLES
- ④ DIESEL GENERATOR SET
- ⑤ BATTERY AND RACK
- ⑥ OIL PRESSURE TANK
- ⑦ AC AND DC SWITCHBOARD AND
- ⑧ BATTERY CHARGER CUBICLE
- ⑨ MAIN CONTROL SWITCHBOARD
- ⑩ SWITCHYARD
- ⑪ NEUTRAL GROUNDING CUBICLE

FLOOR FINISH SYMBOLS :

- ① COARSE FINISHED
- ② 12"x12" CERAMIC FLOOR TILES
- ③ COATED WITH EPOXY RESIN

WALL FINISH SYMBOLS :

- ① CEMENT PLASTER
- ② 8"x8" CERAMIC WALL TILES
- ③ CLASS BLOCK


NOTES :

1. ALL DIMENSIONS AND ELEVATIONS (M.S.L.) ARE IN METERS, UNLESS OTHERWISE SHOWN.
2. SYMBOLS, ABBREVIATIONS AND GENERAL NOTES SEE DWG. NO. KLP-GN-03


REFERENCE DRAWINGS :

- | | |
|---|-----------|
| 1. POWERHOUSE, GENERAL LAY-OUT | KLP-PH-01 |
| 2. POWERHOUSE, PLAN 2nd FLOOR | KLP-PH-03 |
| 3. POWERHOUSE, ELEVATIONS | KLP-PH-04 |
| 4. POWERHOUSE, SECTIONS | KLP-PH-05 |
| 5. POWERHOUSE, DETAILS OF TOILET, AND BUCKET TREATS | KLP-PH-07 |
| 6. POWERHOUSE, DETAIL OF DOORS, WINDOWS AND NAMEPLATE | KLP-PH-08 |

KINGDOM OF THAILAND Department of Alternative Energy Development and Efficiency MINISTRY OF ENERGY	
KLONG LAM PLOK HYDROPOWER PROJECT	
CIVIL WORKS AND TRANSMISSION LINE POWERHOUSE PLAN 1st FLOOR	
P&C MANAGEMENT CO.,LTD. DESIGNED: <i>[Signature]</i> 25.29074 DRAWN: <i>[Signature]</i> CHECKED: <i>[Signature]</i> 25.6226 PROJECT MANAGER	Department of Alternative Energy Development and Efficiency MINISTRY OF ENERGY REVIEWED: <i>[Signature]</i> SUBMITTED: <i>[Signature]</i> RECOMMENDED: <i>[Signature]</i> APPROVED: <i>[Signature]</i> DRAWING NO. KLP-PH-02 SHEET NO. 74 OF 110

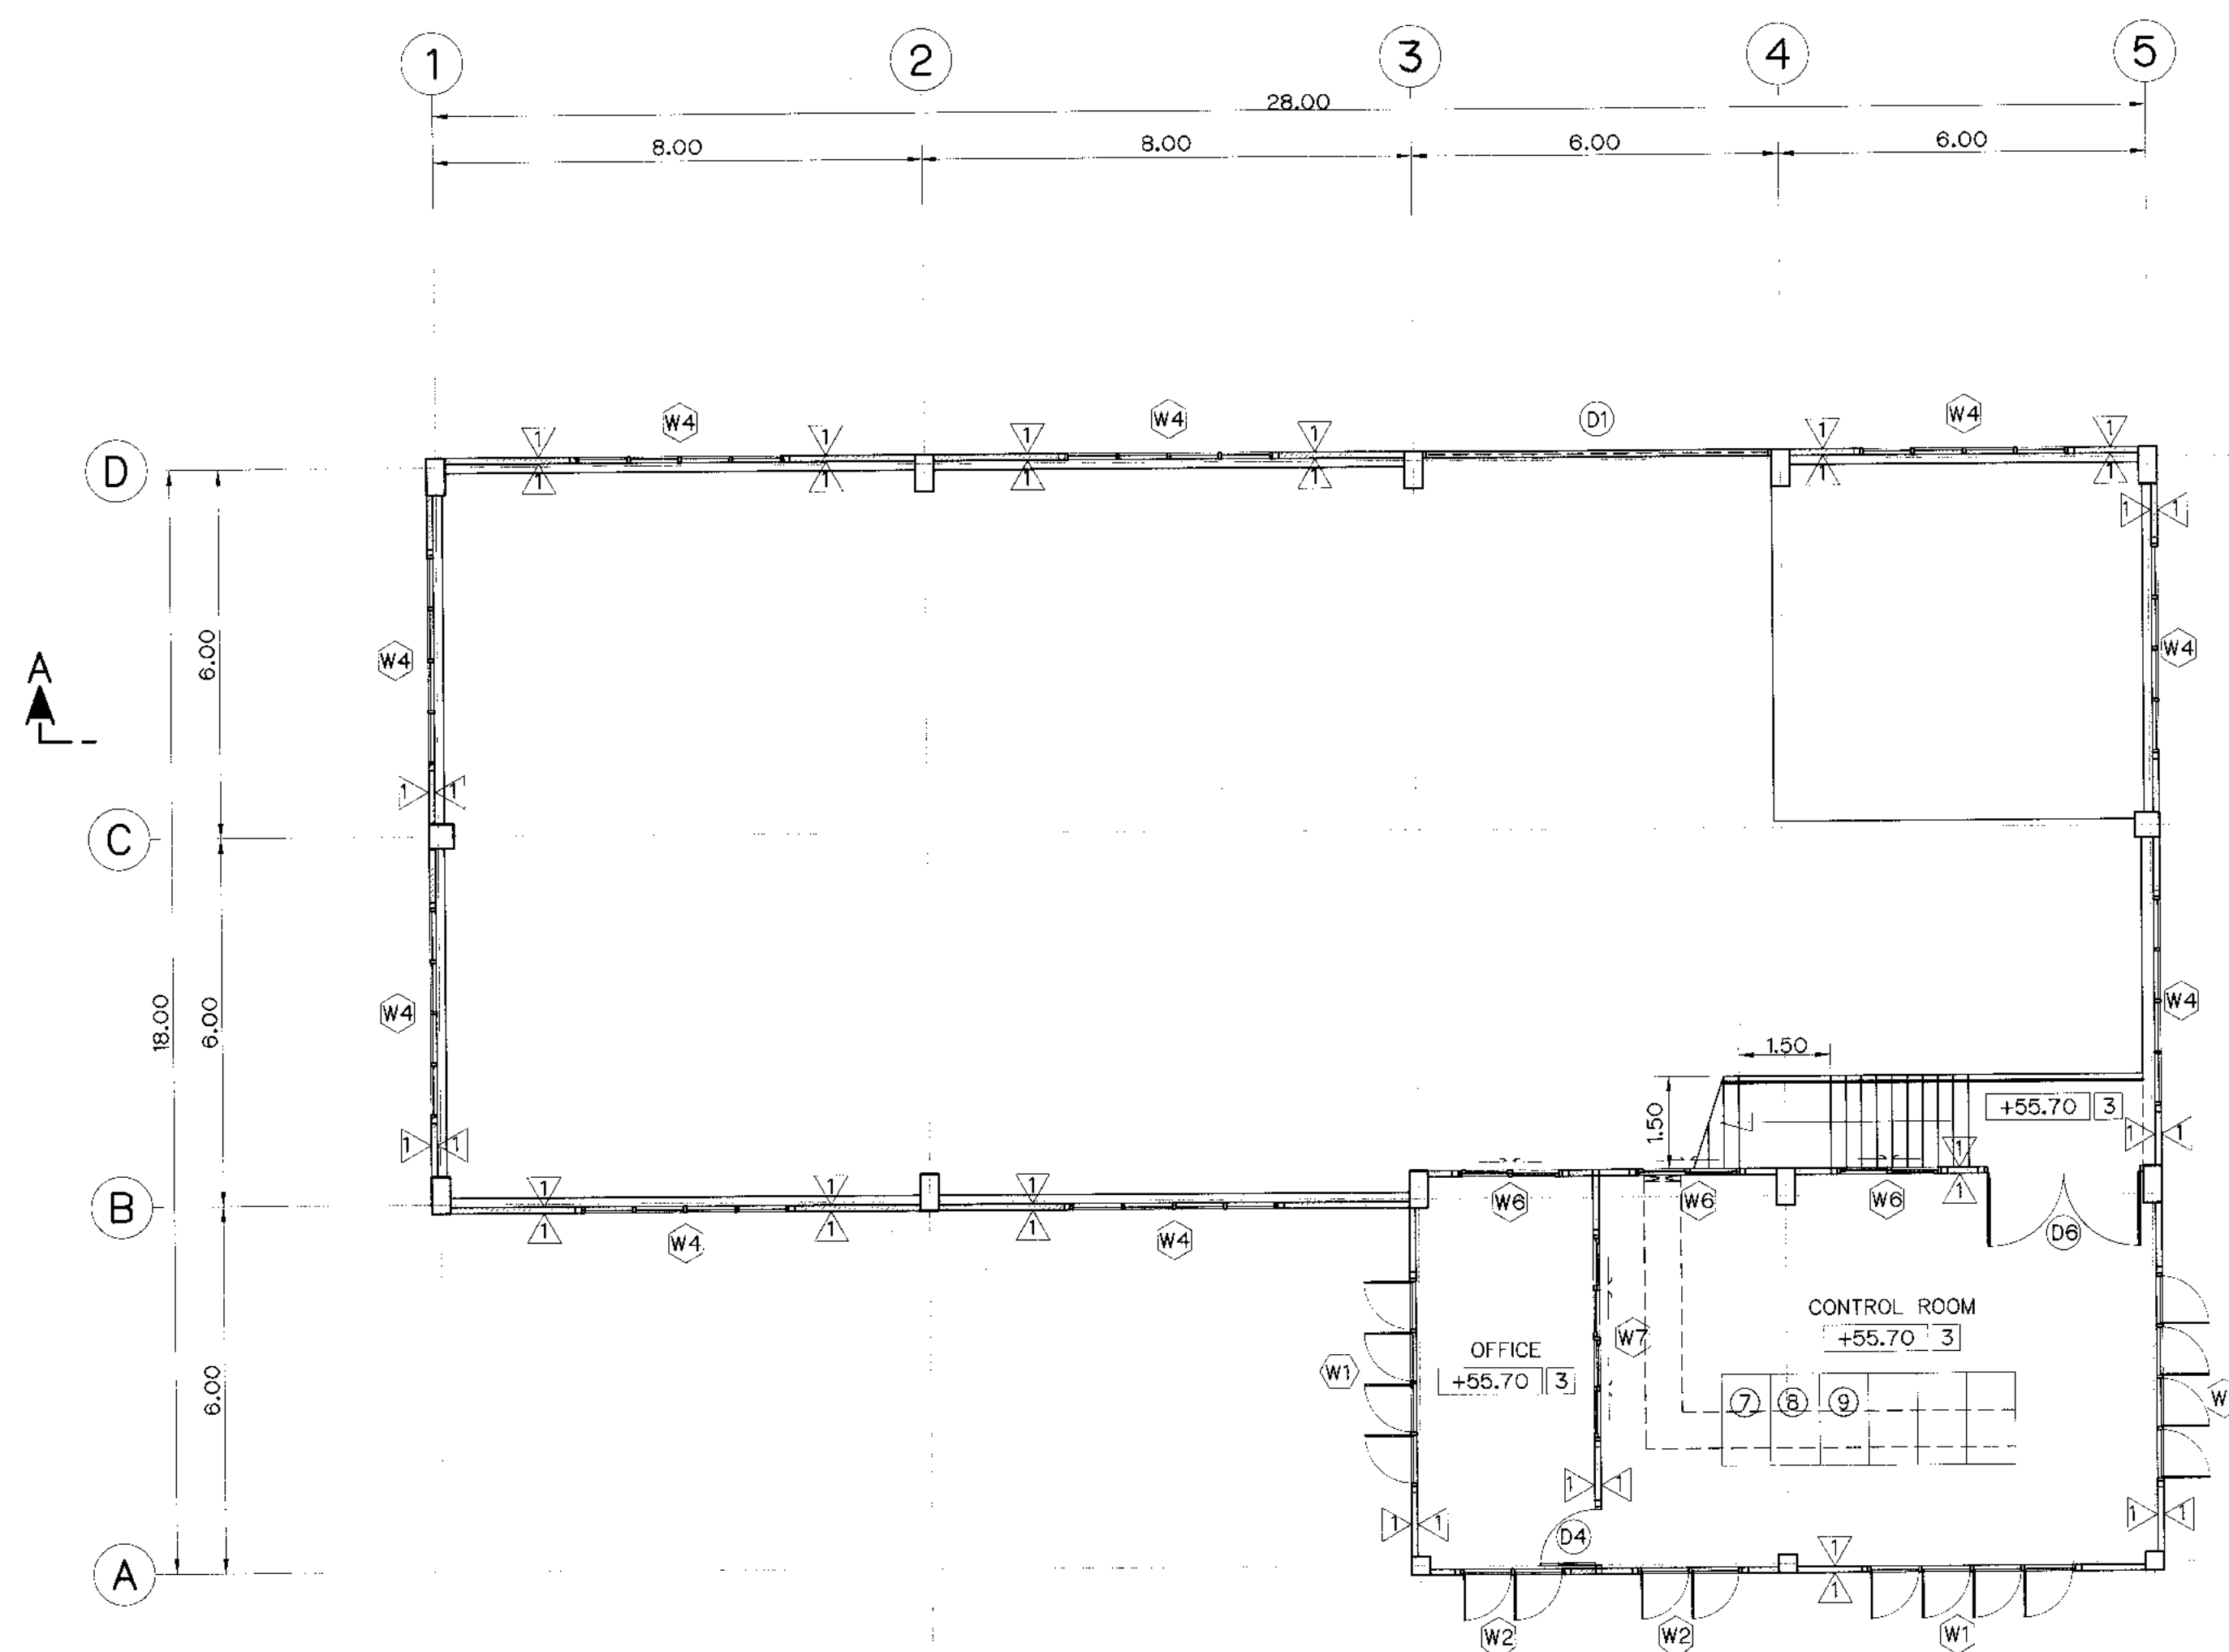

PLAN 2nd FLOOR
SCALE 1:100

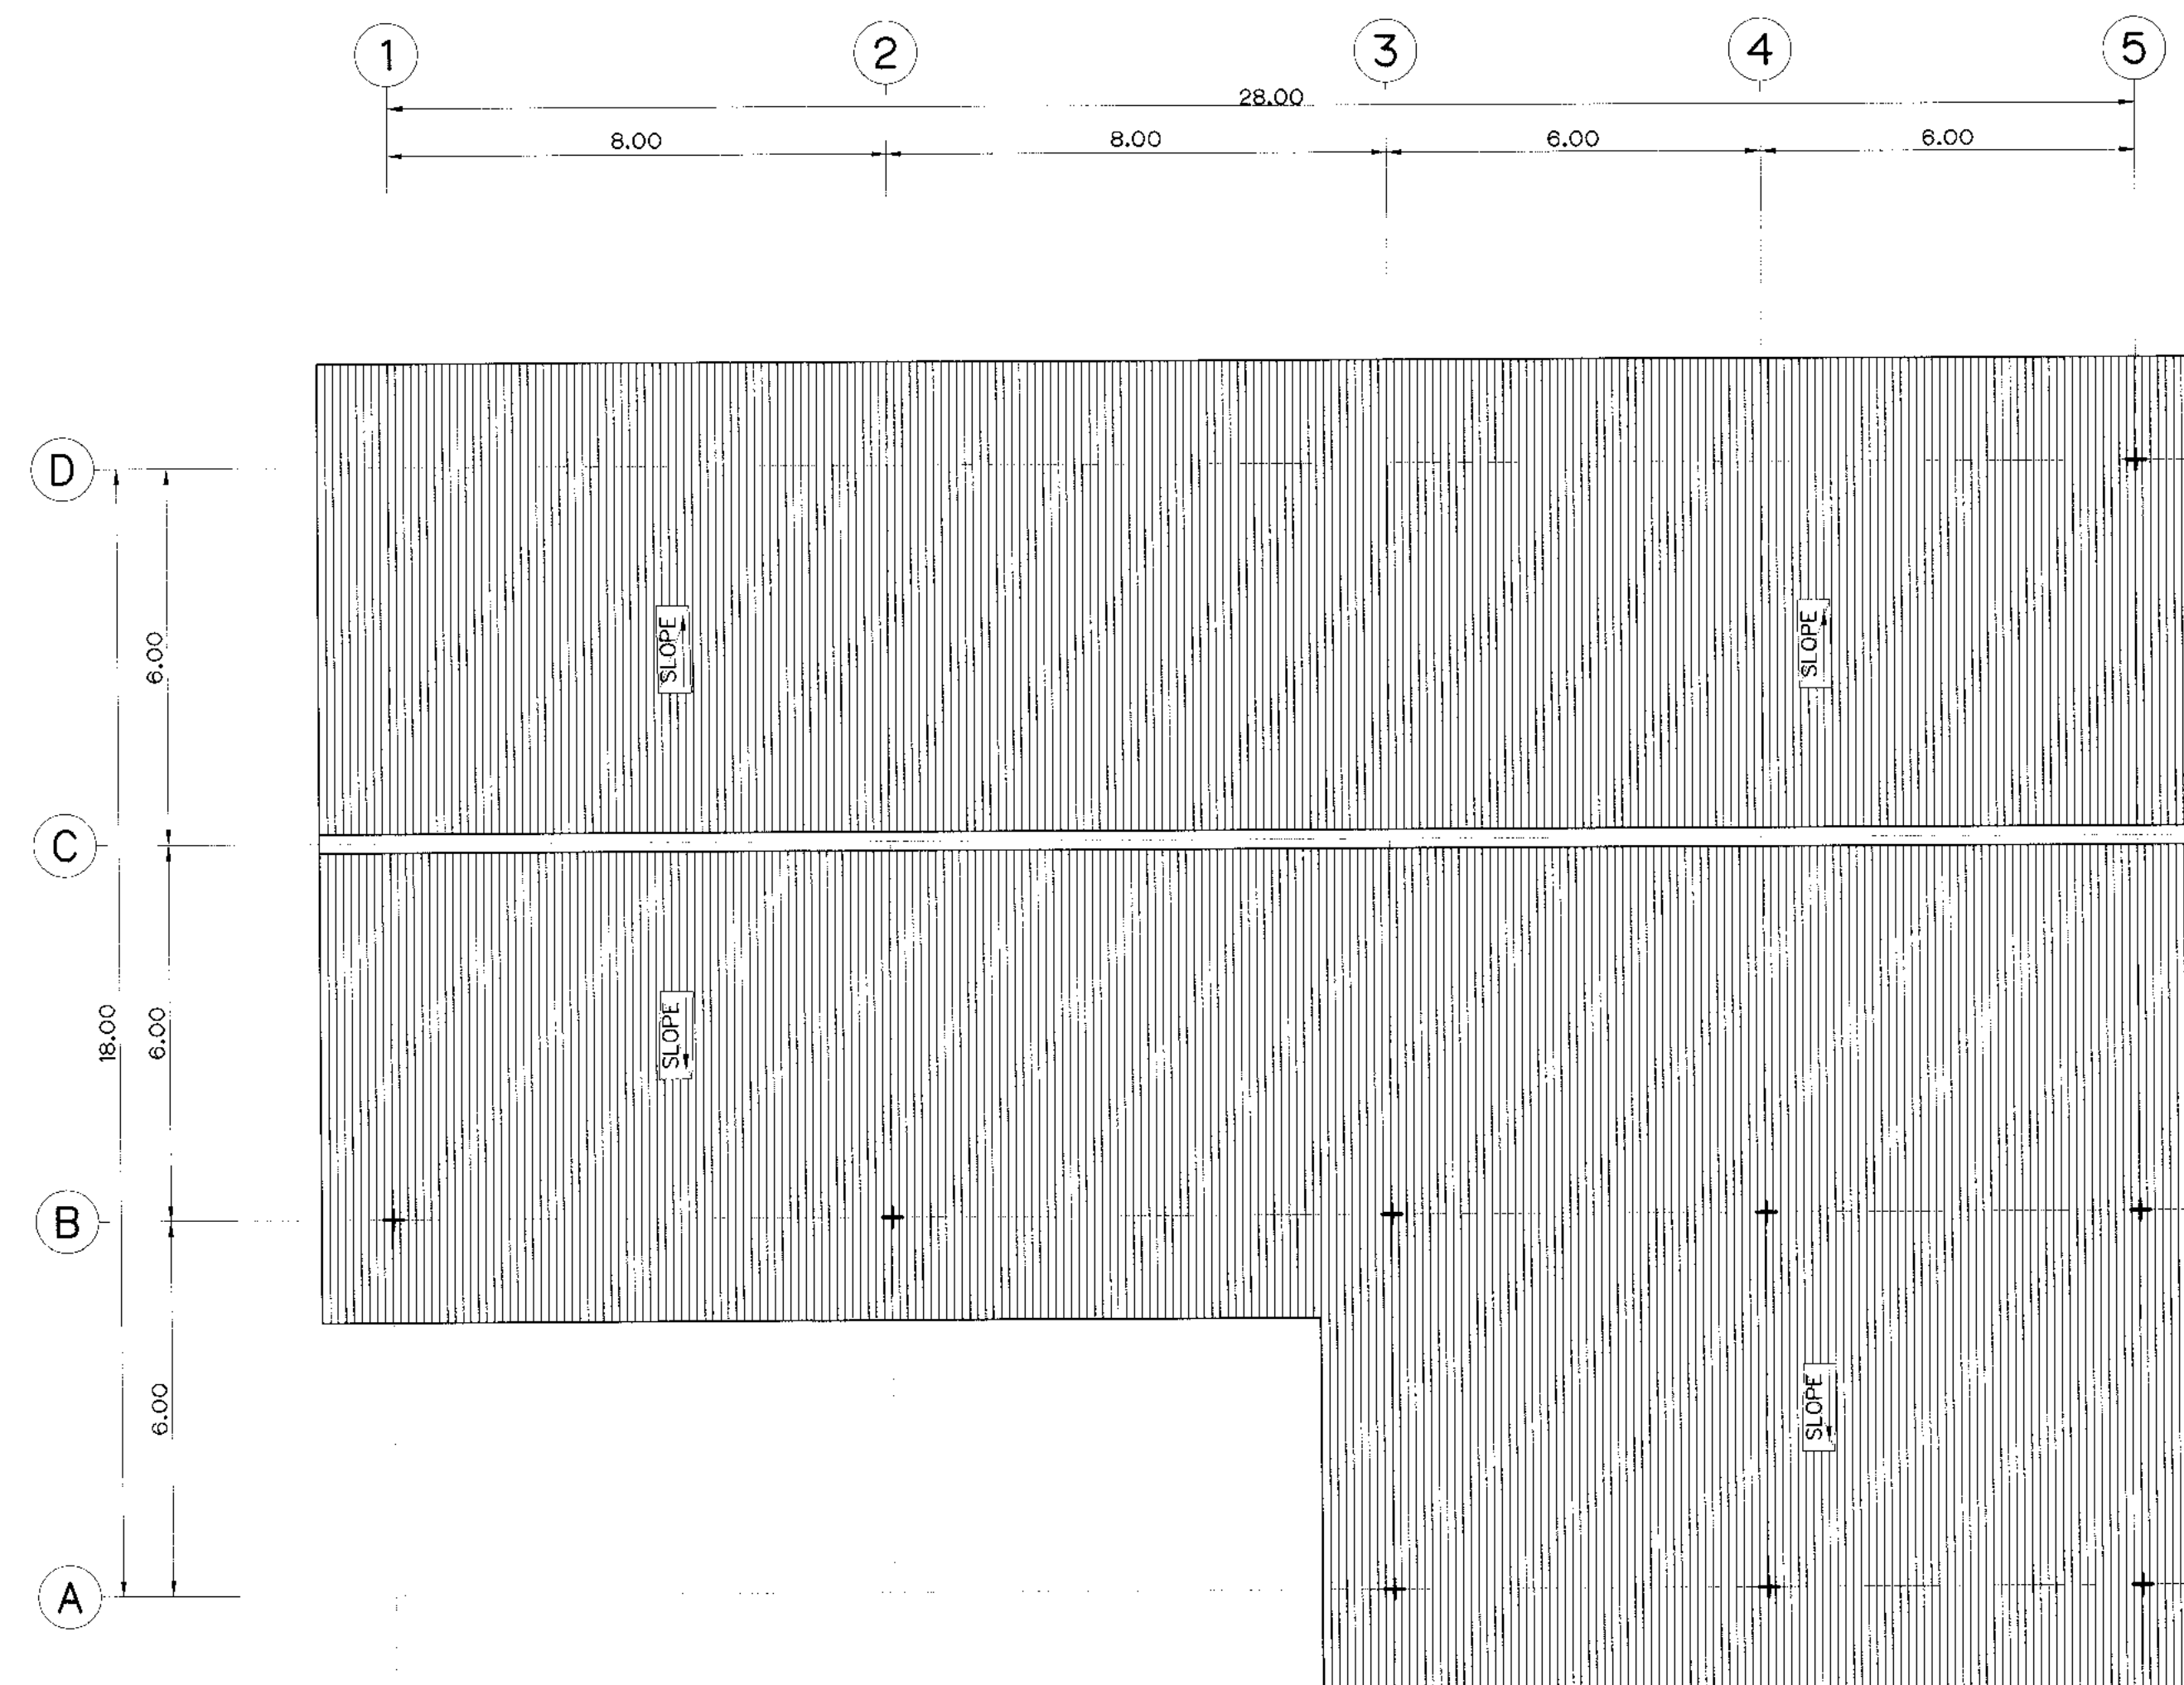

ROOF PLAN
SCALE 1:100

NOTES :

1. ALL DIMENSIONS AND ELEVATIONS (M.S.L.) ARE IN METERS, UNLESS OTHERWISE SHOWN.
2. SYMBOLS, ABBREVIATIONS AND GENERAL NOTES SEE DWG. NO. KLP-GN-03





REFERENCE DRAWINGS :

- | | |
|---------------------------|-----------|
| 1. PLAN 1st FLOOR | KLP-PH-02 |
| 2. POWERHOUSE, ELEVATIONS | KLP-PH-04 |



3				
2				
1				
NO.	DATE	REVISIONS	CHECKED	APPROVED
CONSULTANTS			DEDE	

KINGDOM OF THAILAND Department of Alternative Energy Development and Efficiency MINISTRY OF ENERGY			
KLONG LAM PLOK HYDROPOWER PROJECT			
CIVIL WORKS AND TRANSMISSION LINE			
POWERHOUSE			
PLAN 2nd AND ROOF PLAN			
P&C MANAGEMENT CO.,LTD.		Department of Alternative Energy Development and Efficiency MINISTRY OF ENERGY	
DESIGNED 18.20074 28.6226		REVIEWED	
DRAWN		SUBMITTED	
CHECKED 28.6226		RECOMMENDED	
PROJECT MANAGER		APPROVED	
09/03/2559 DATE		DRAWING NO.	
		KLP-PH-03	
		SHEET NO.	
		75 OF 110	

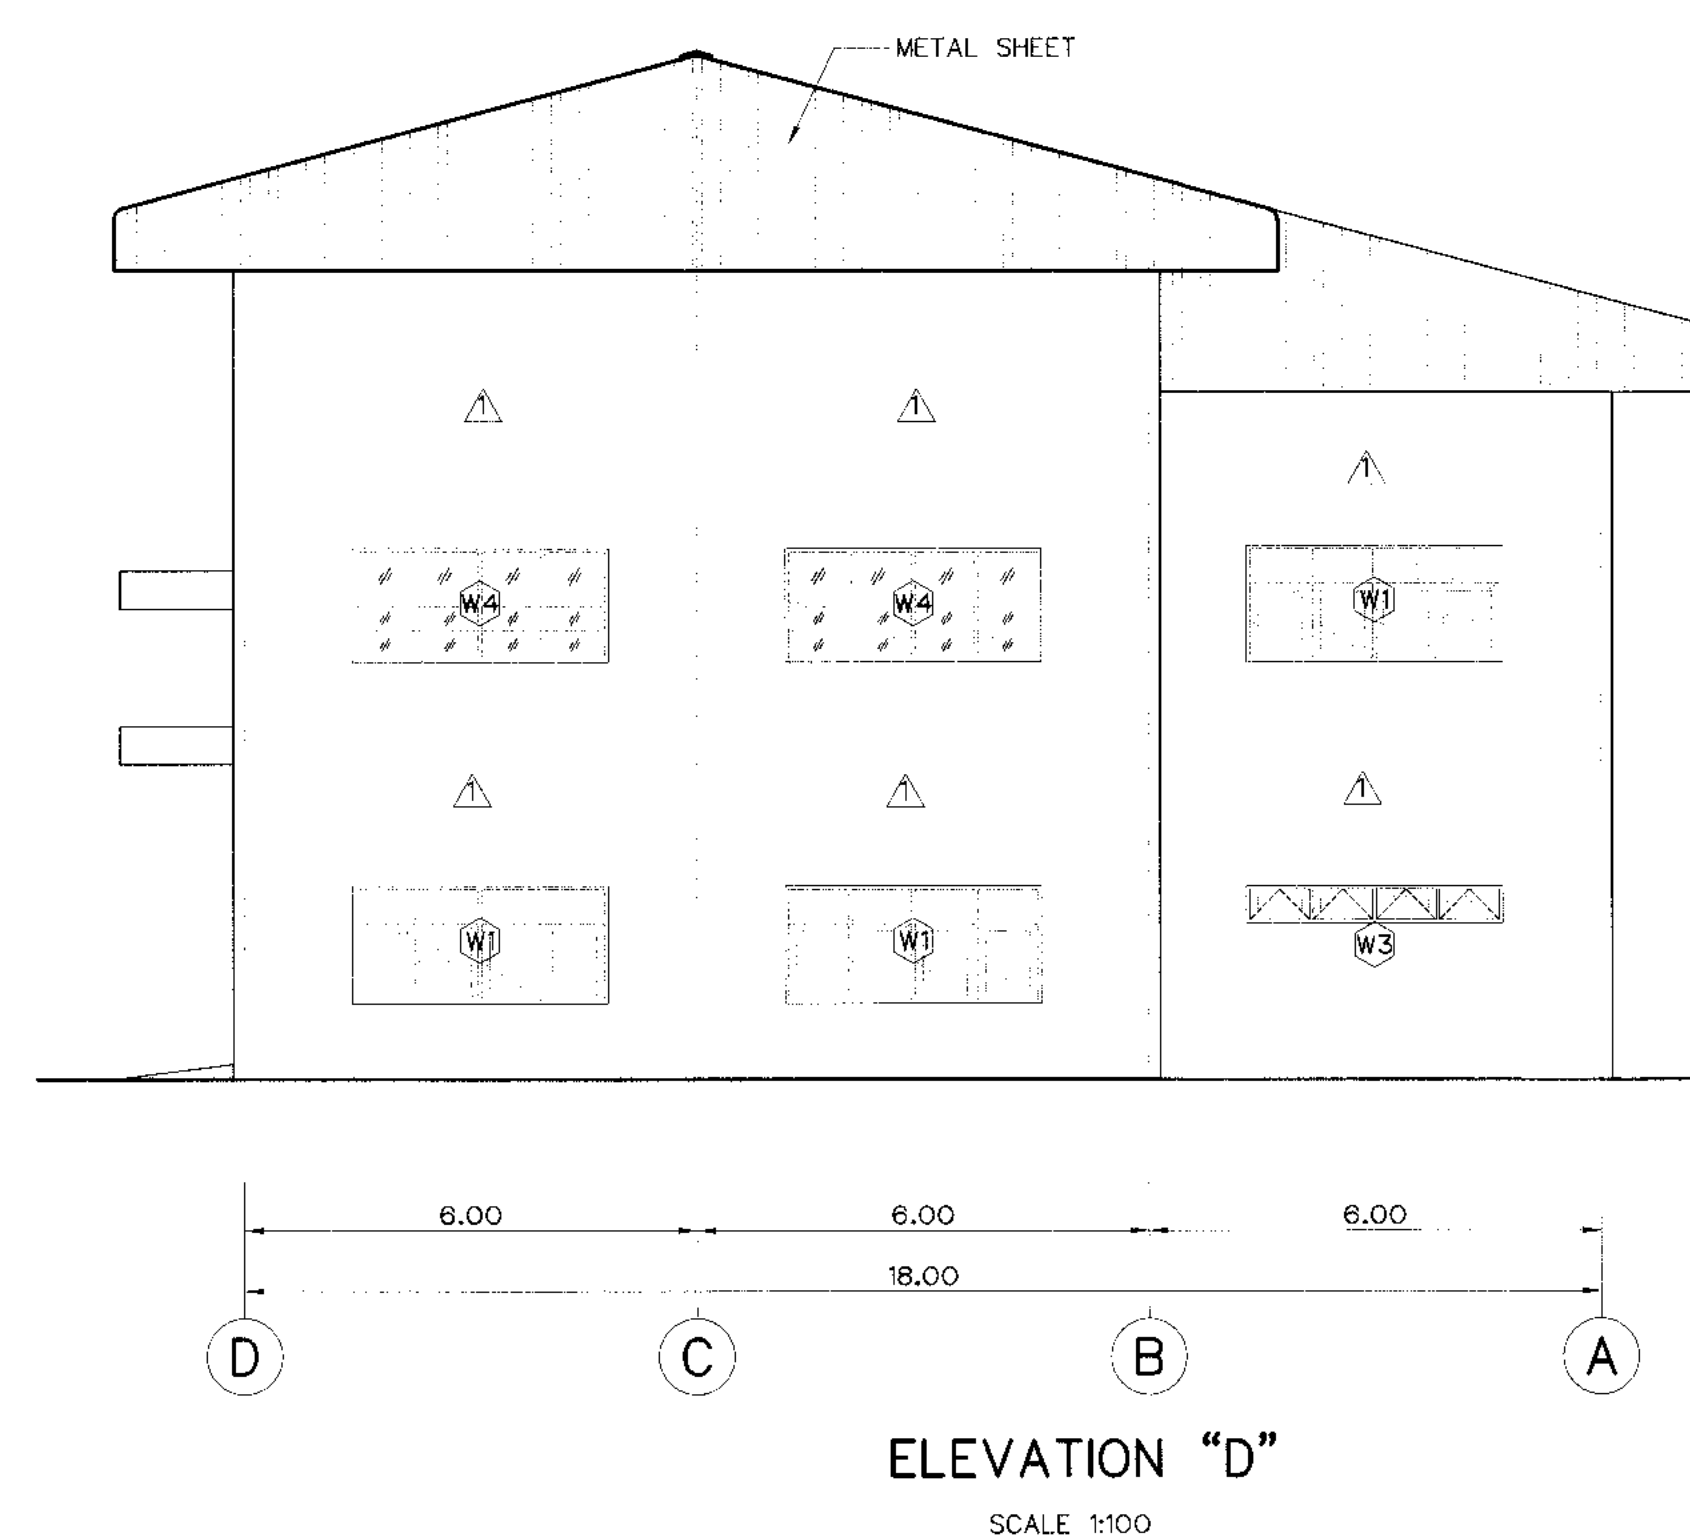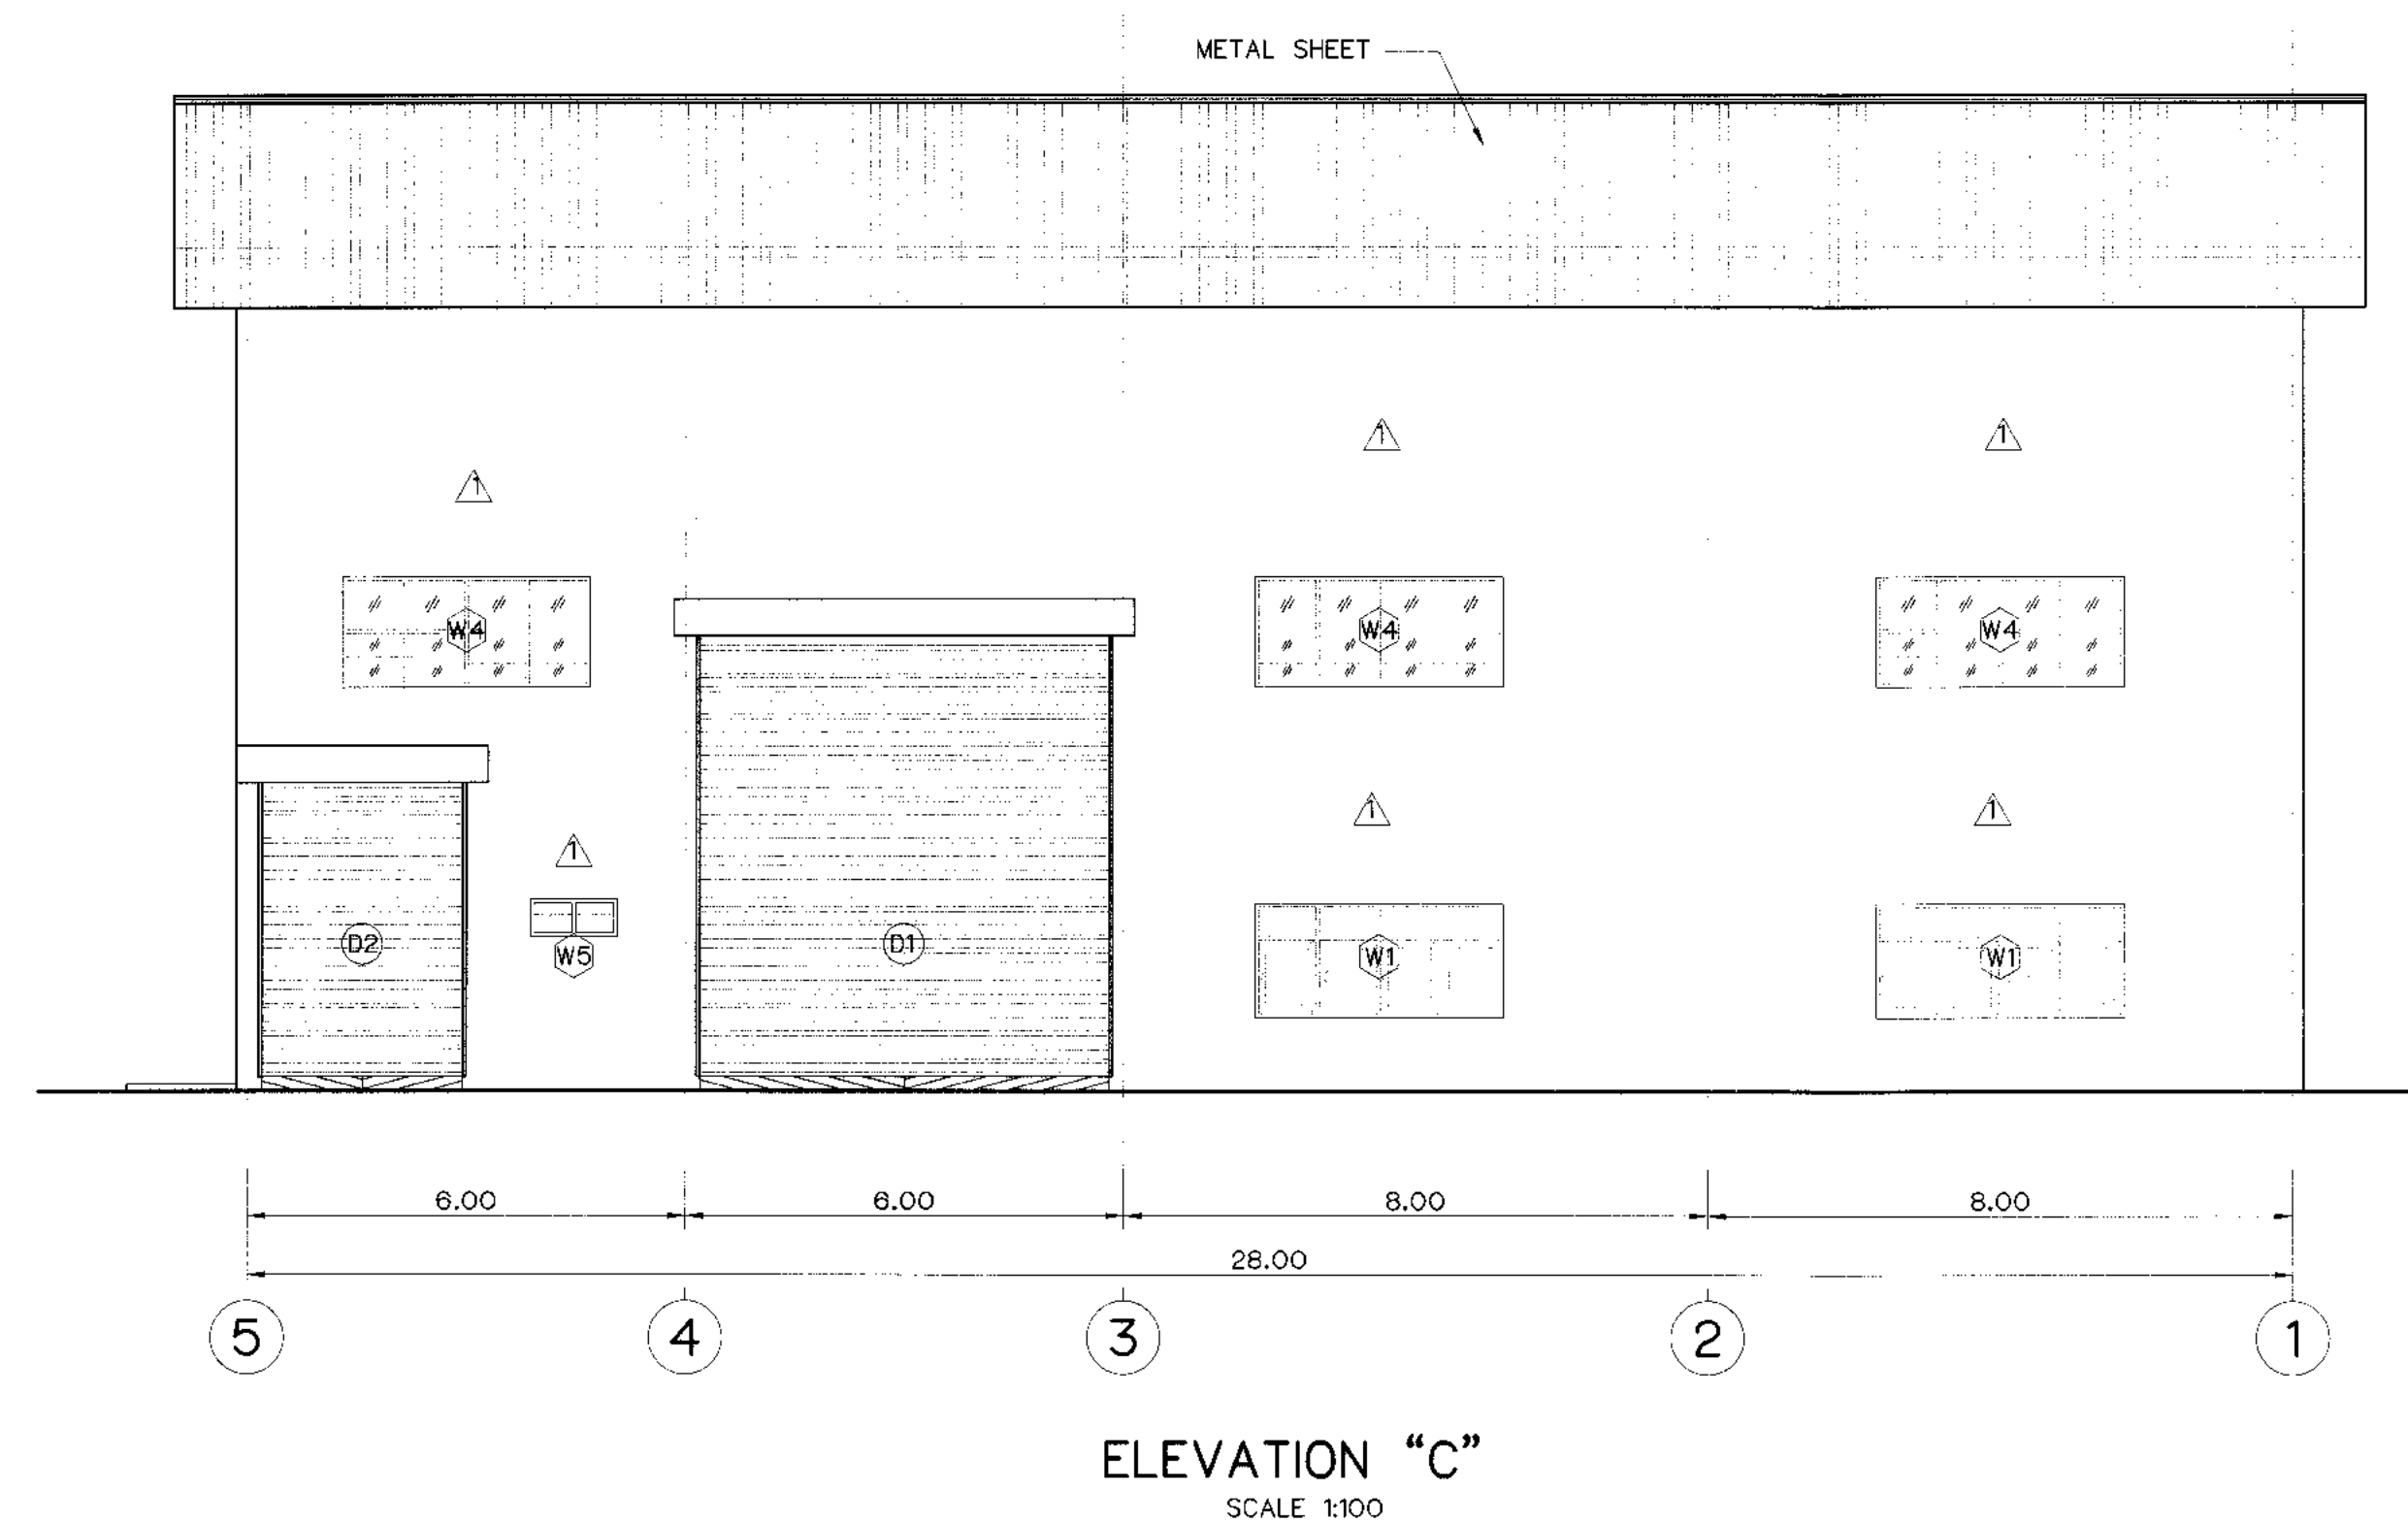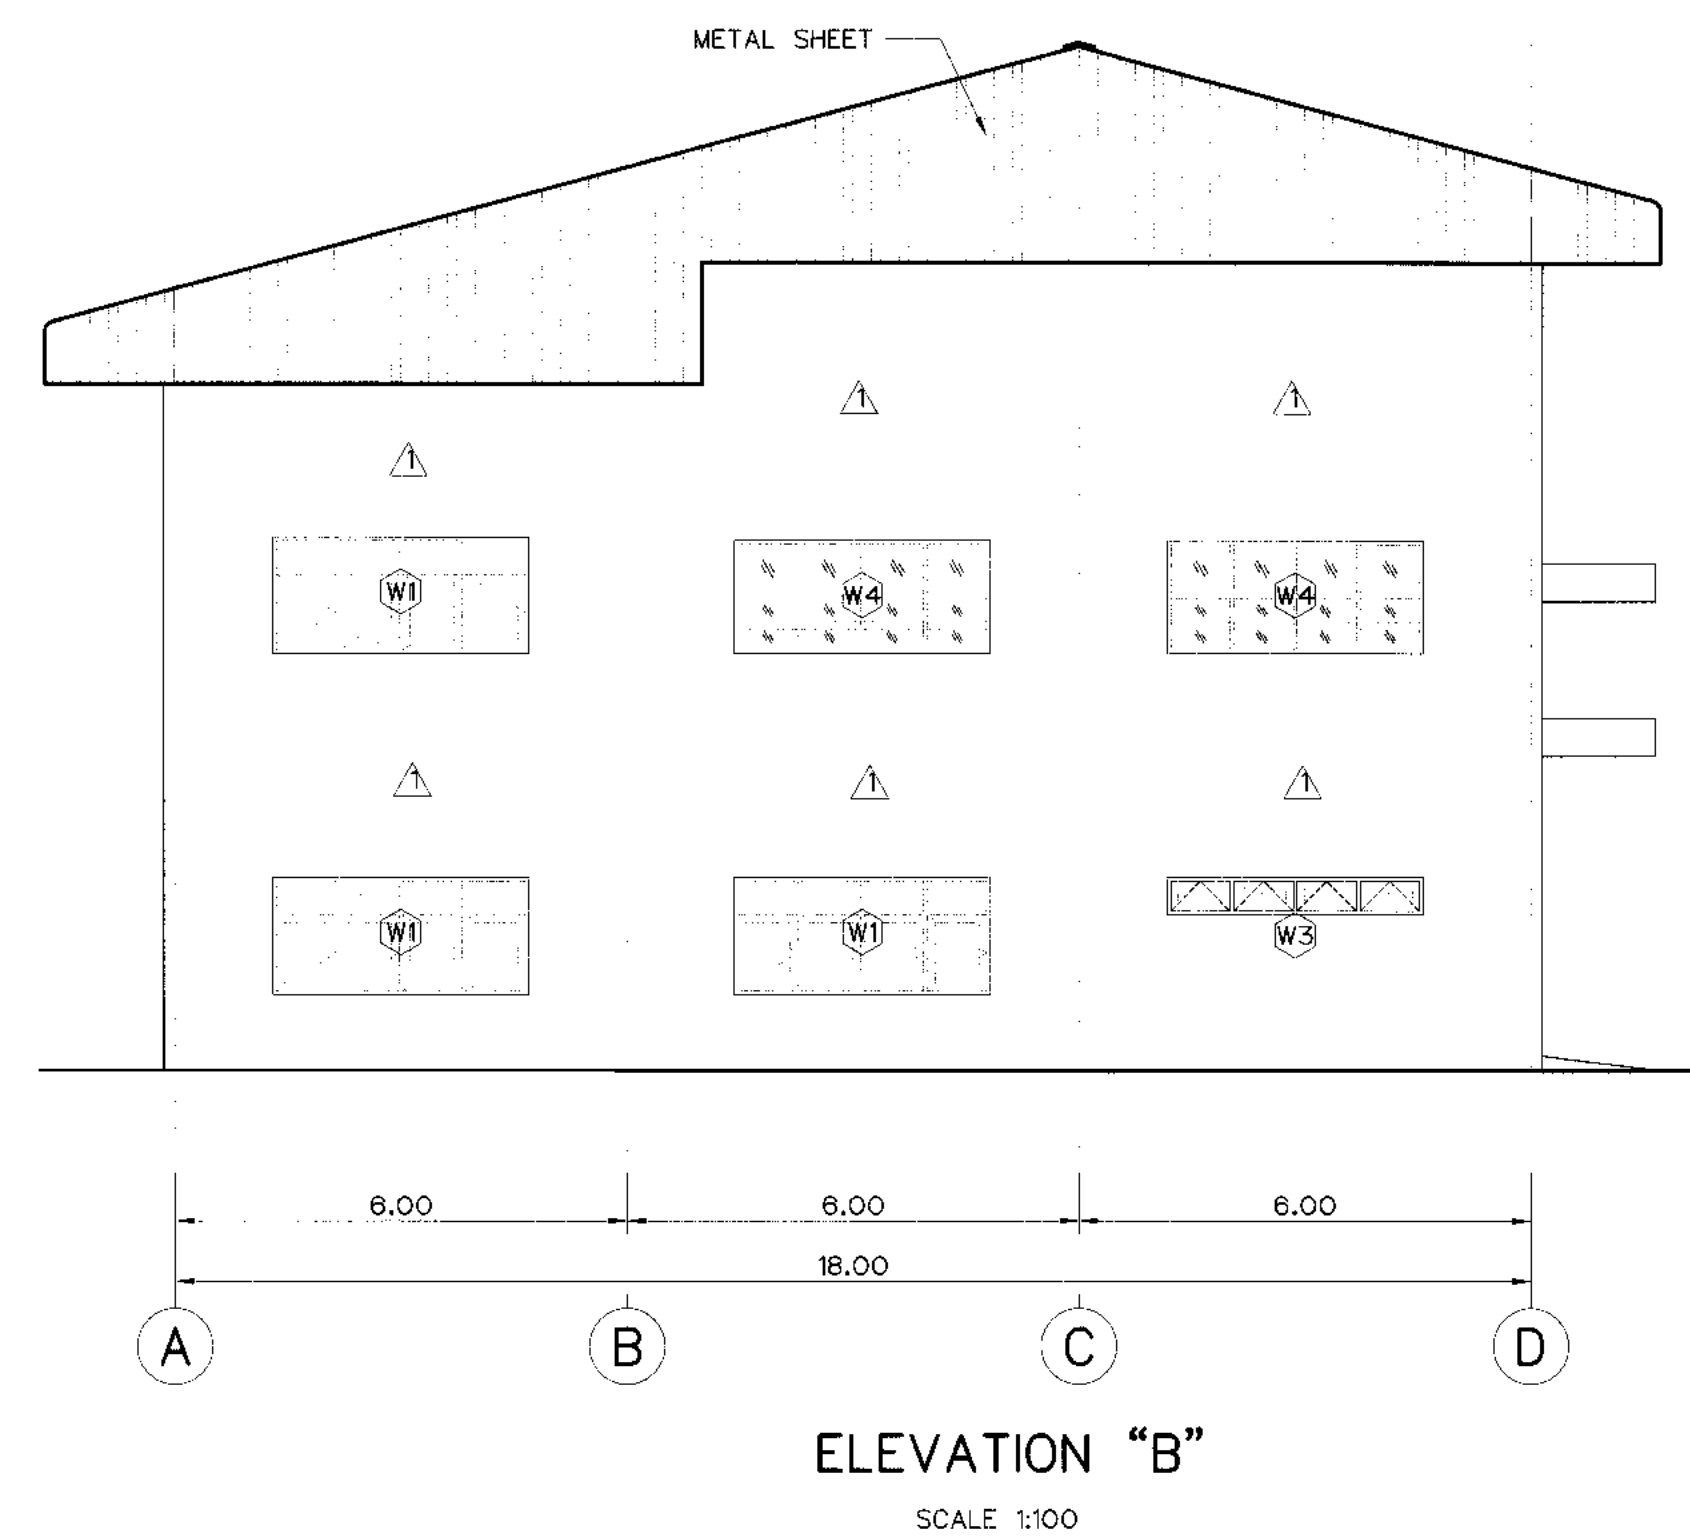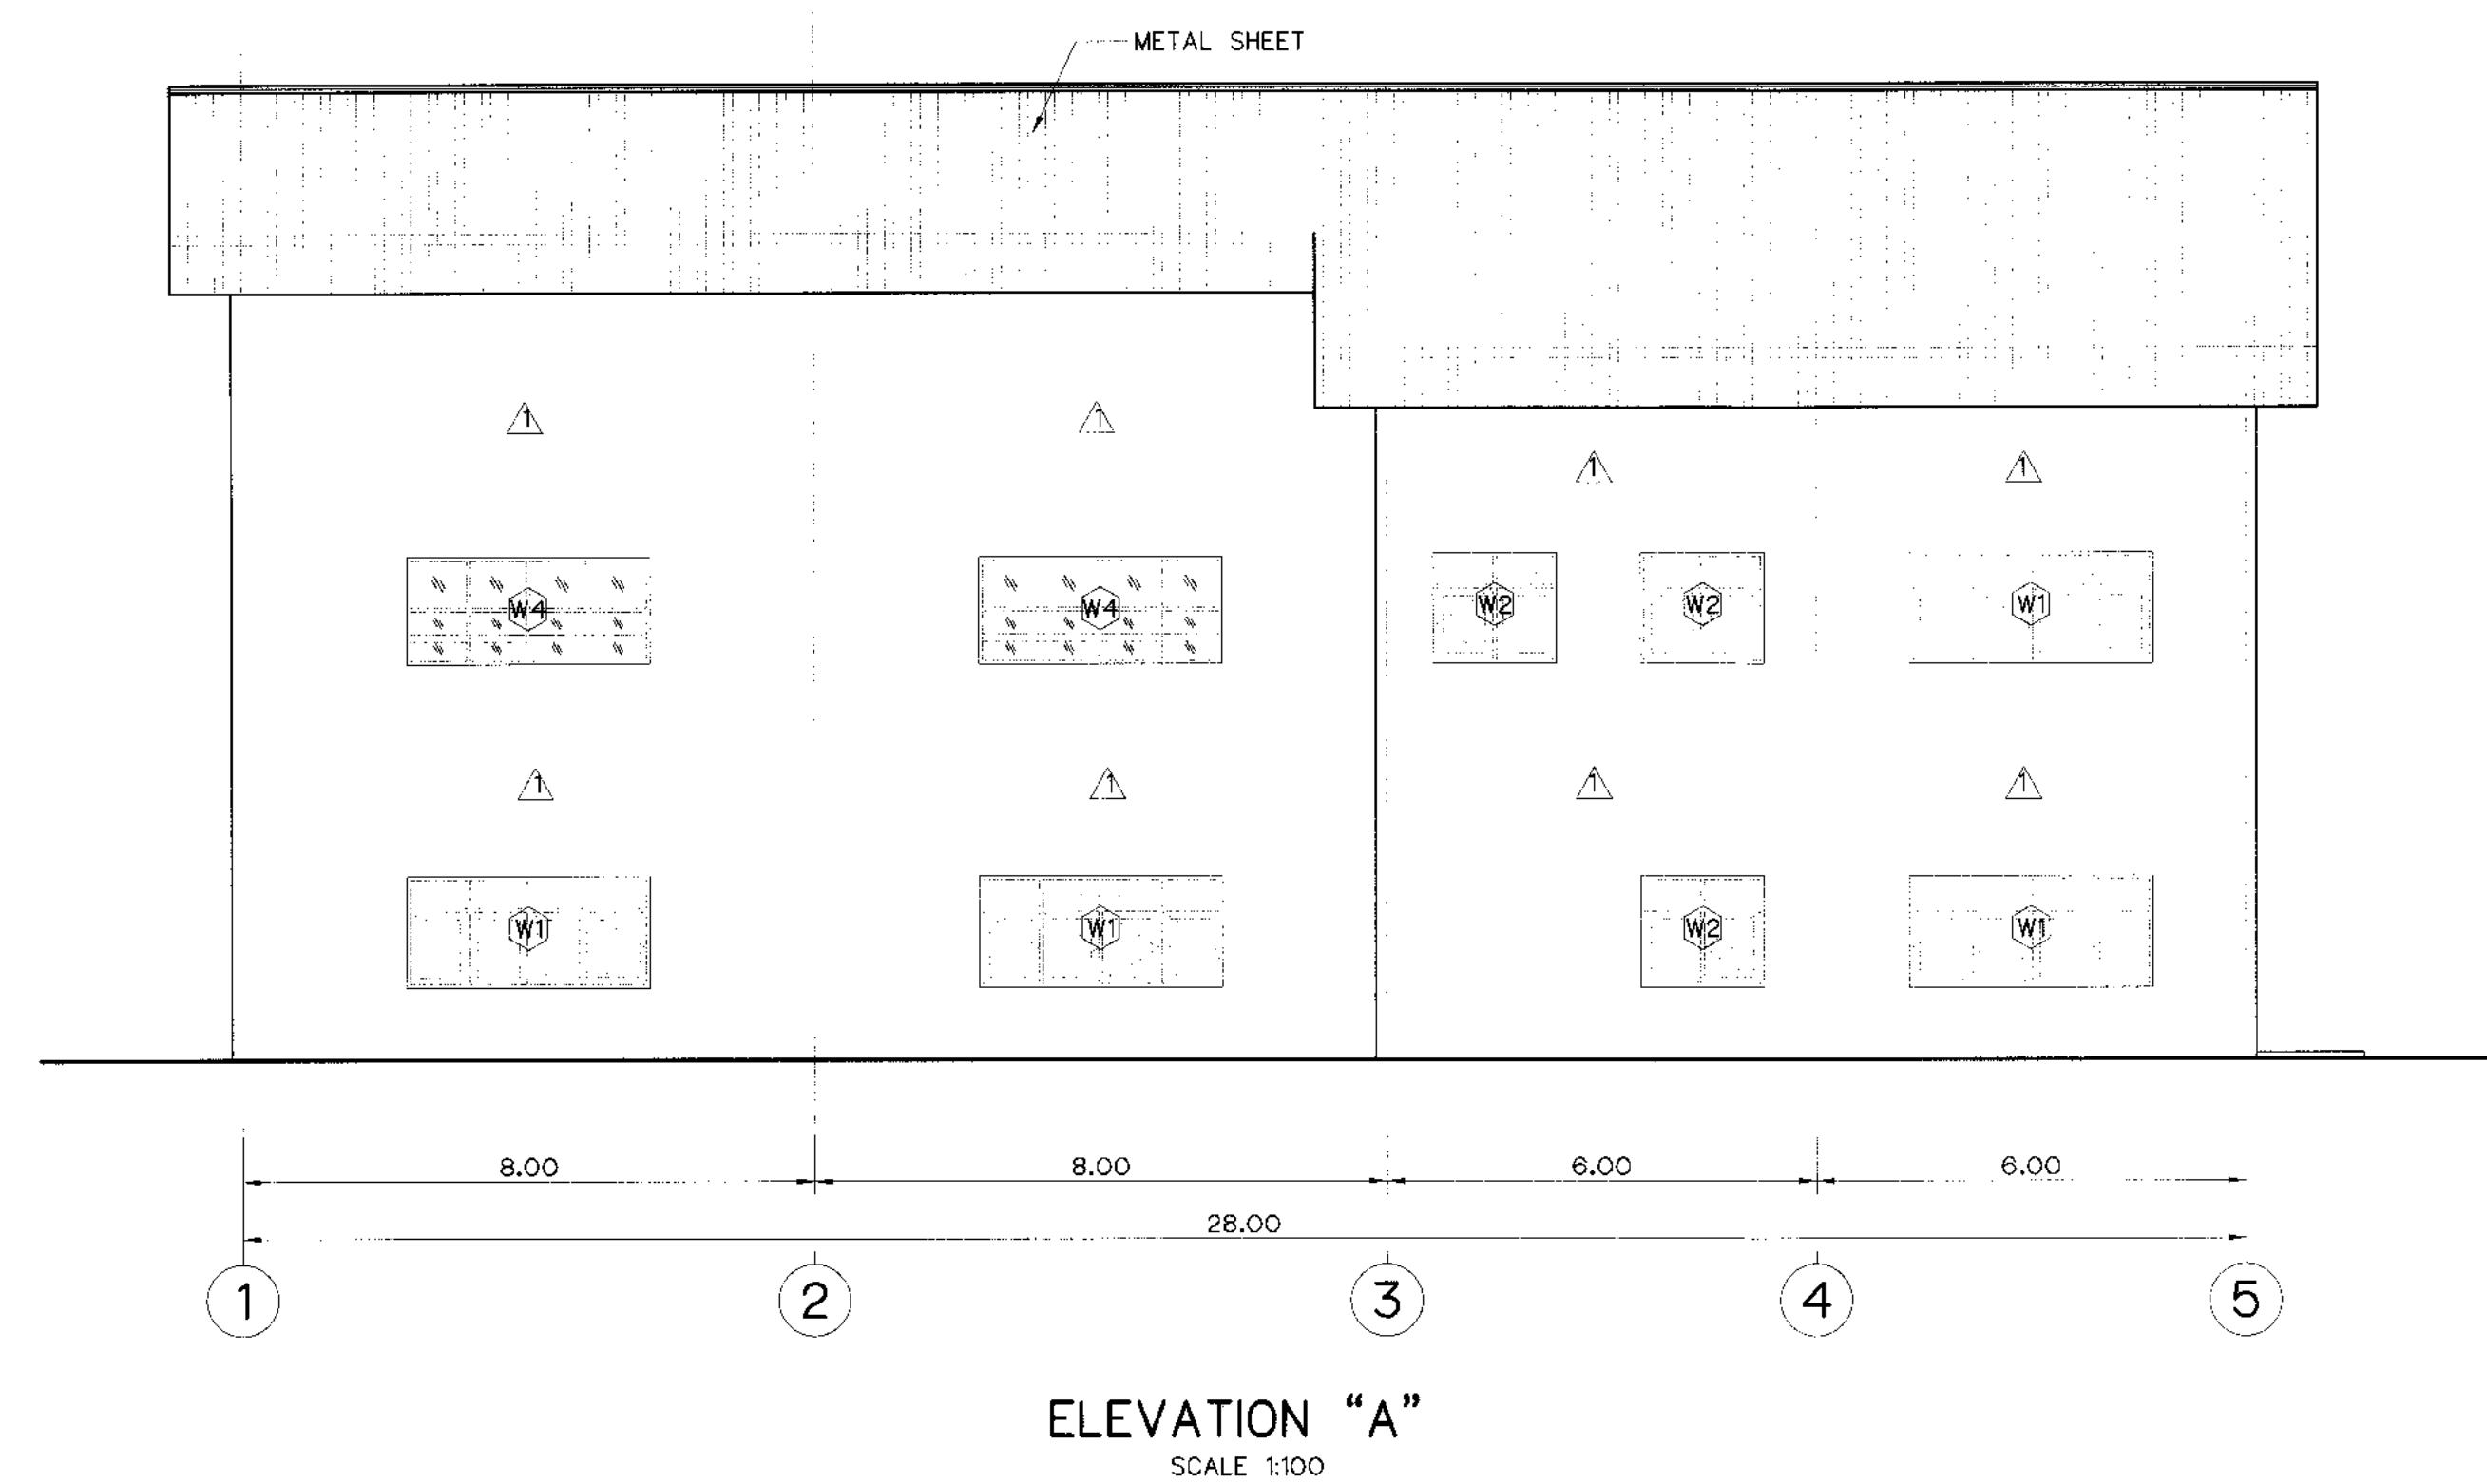


NOTES :

1. ALL DIMENSIONS AND ELEVATIONS (M.S.L.) ARE IN METERS,
UNLESS OTHERWISE SHOWN.
2. SYMBOLS, ABBREVIATIONS AND GENERAL NOTES SEE DWG. NO. KLP-GN-03


REFERENCE DRAWINGS :

- | | |
|---------------------------|-----------|
| 1. PLAN 1st FLOOR | KLP-PH-02 |
| 2. PLAN 2nd AND ROOF PLAN | KLP-PH-03 |

3				
2				
1				
NO.	DATE	REVISIONS	CHECKED	APPROVED
CONSULTANTS			DEDE	

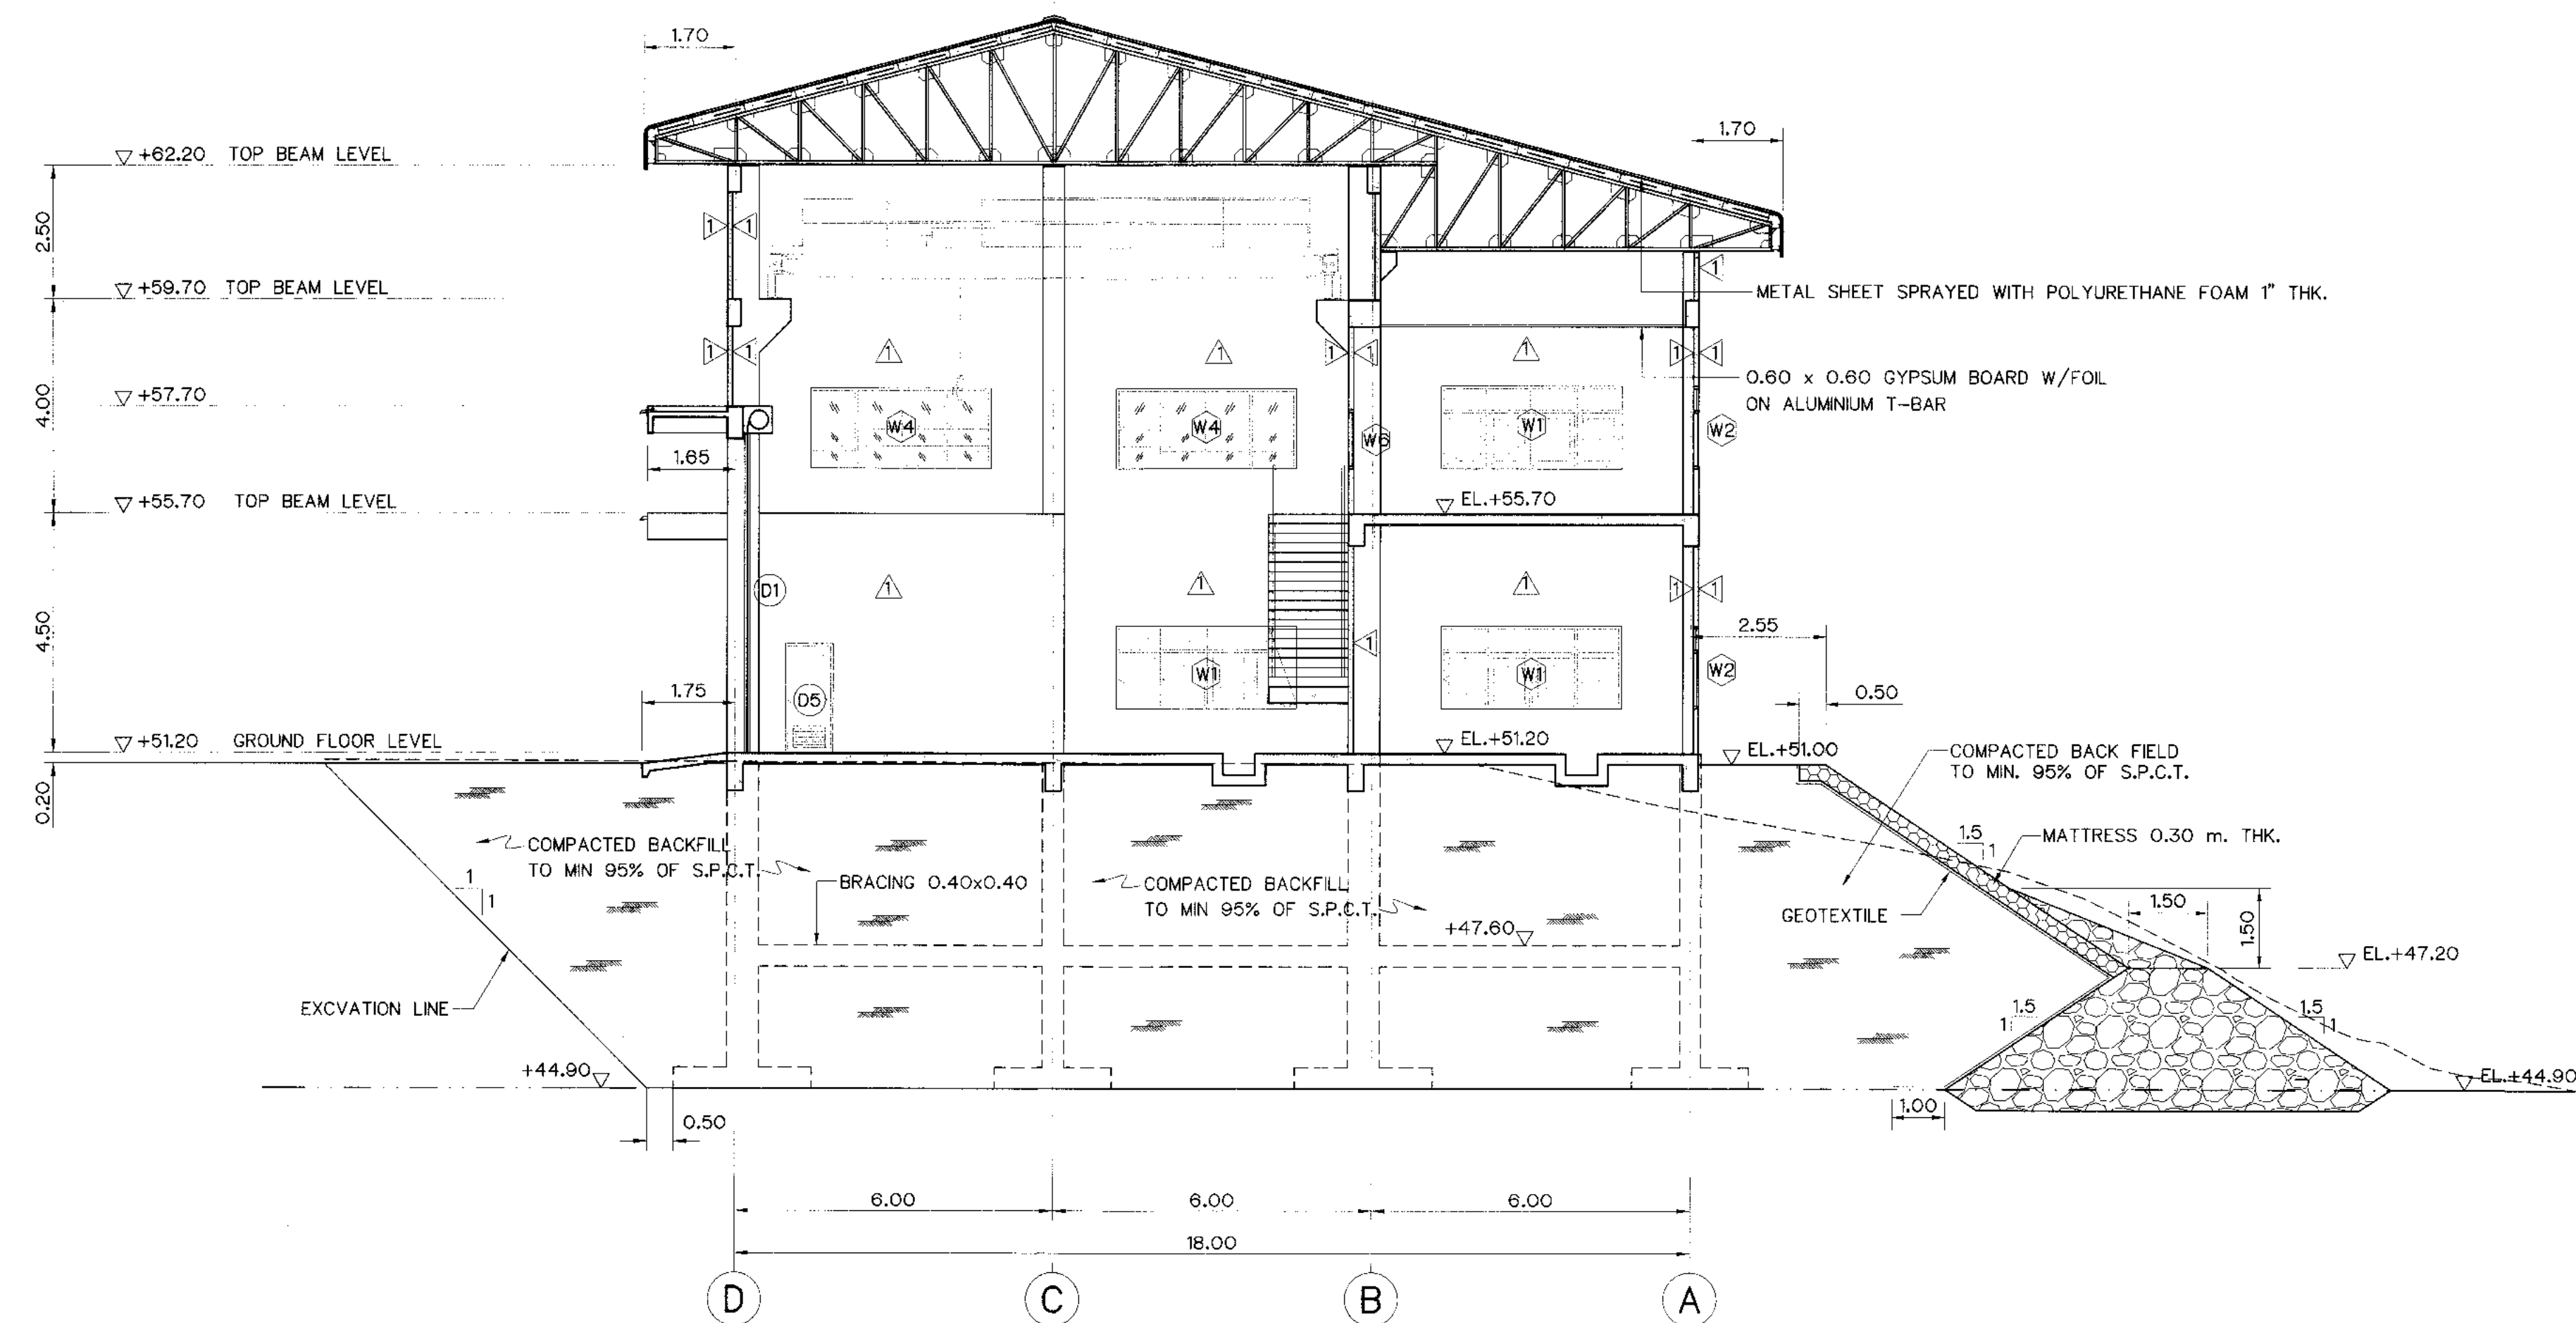

SECTION C-C
SCALE 1:100

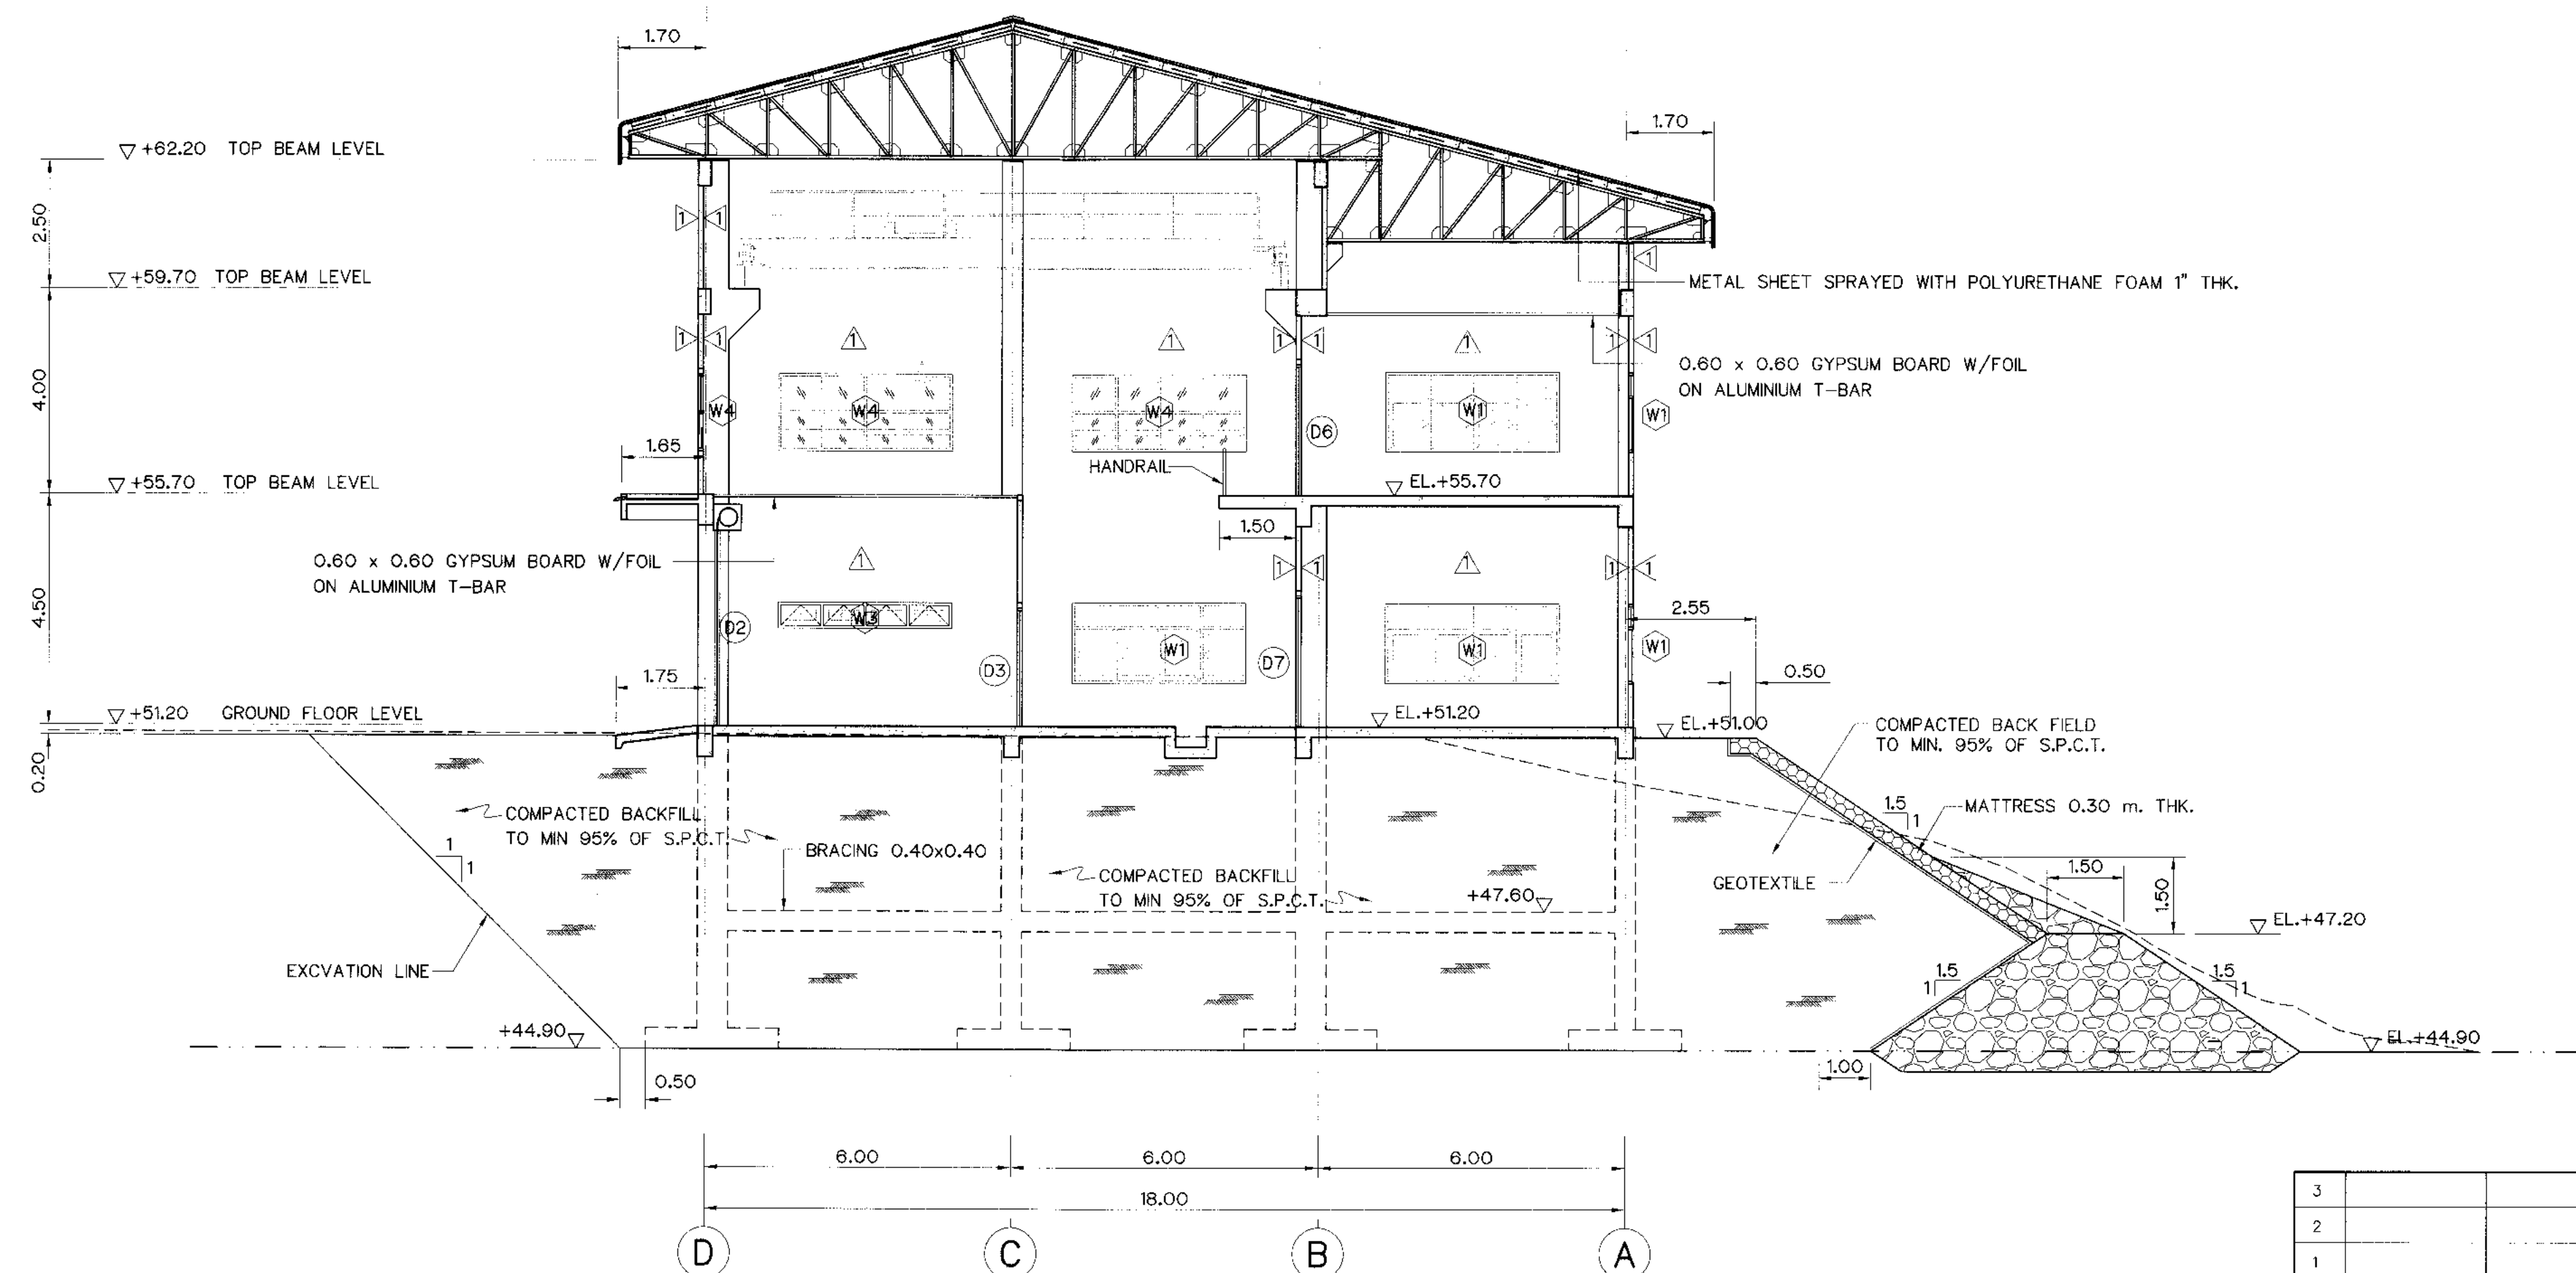

SECTION D-D
SCALE 1:100

NOTES :


1. ALL DIMENSIONS AND ELEVATIONS (M.S.L.) ARE IN METERS, UNLESS OTHERWISE SHOWN.
2. SYMBOLS, ABBREVIATIONS AND GENERAL NOTES SEE DWG. NO. KLP-GN-03

REFERENCE DRAWINGS :


- | | |
|---------------------------|-----------|
| 1. PLAN 1st FLOOR | KLP-PH-02 |
| 2. PLAN 2nd AND ROOF PLAN | KLP-PH-03 |
| 3. ELEVATIONS | KLP-PH-04 |




KINGDOM OF THAILAND Department of Alternative Energy Development and Efficiency MINISTRY OF ENERGY	
KLONG LAM PLOK HYDROPOWER PROJECT	
CIVIL WORKS AND TRANSMISSION LINE POWERHOUSE SECTIONS (SHEET 2/2)	
P&C MANAGEMENT CO., LTD. DESIGNED <i>[Signature]</i> #19.29074 DRAWN <i>[Signature]</i> NO. DATE REVISIONS CHECKED APPROVED CONSULTANTS DEDE	MINISTRY OF ENERGY REVIEWED <i>[Signature]</i> SUBMITTED <i>[Signature]</i> RECOMMENDED <i>[Signature]</i> APPROVED <i>[Signature]</i> DRAWING NO. KLP-PH-06 SHEET NO. 78 OF 110

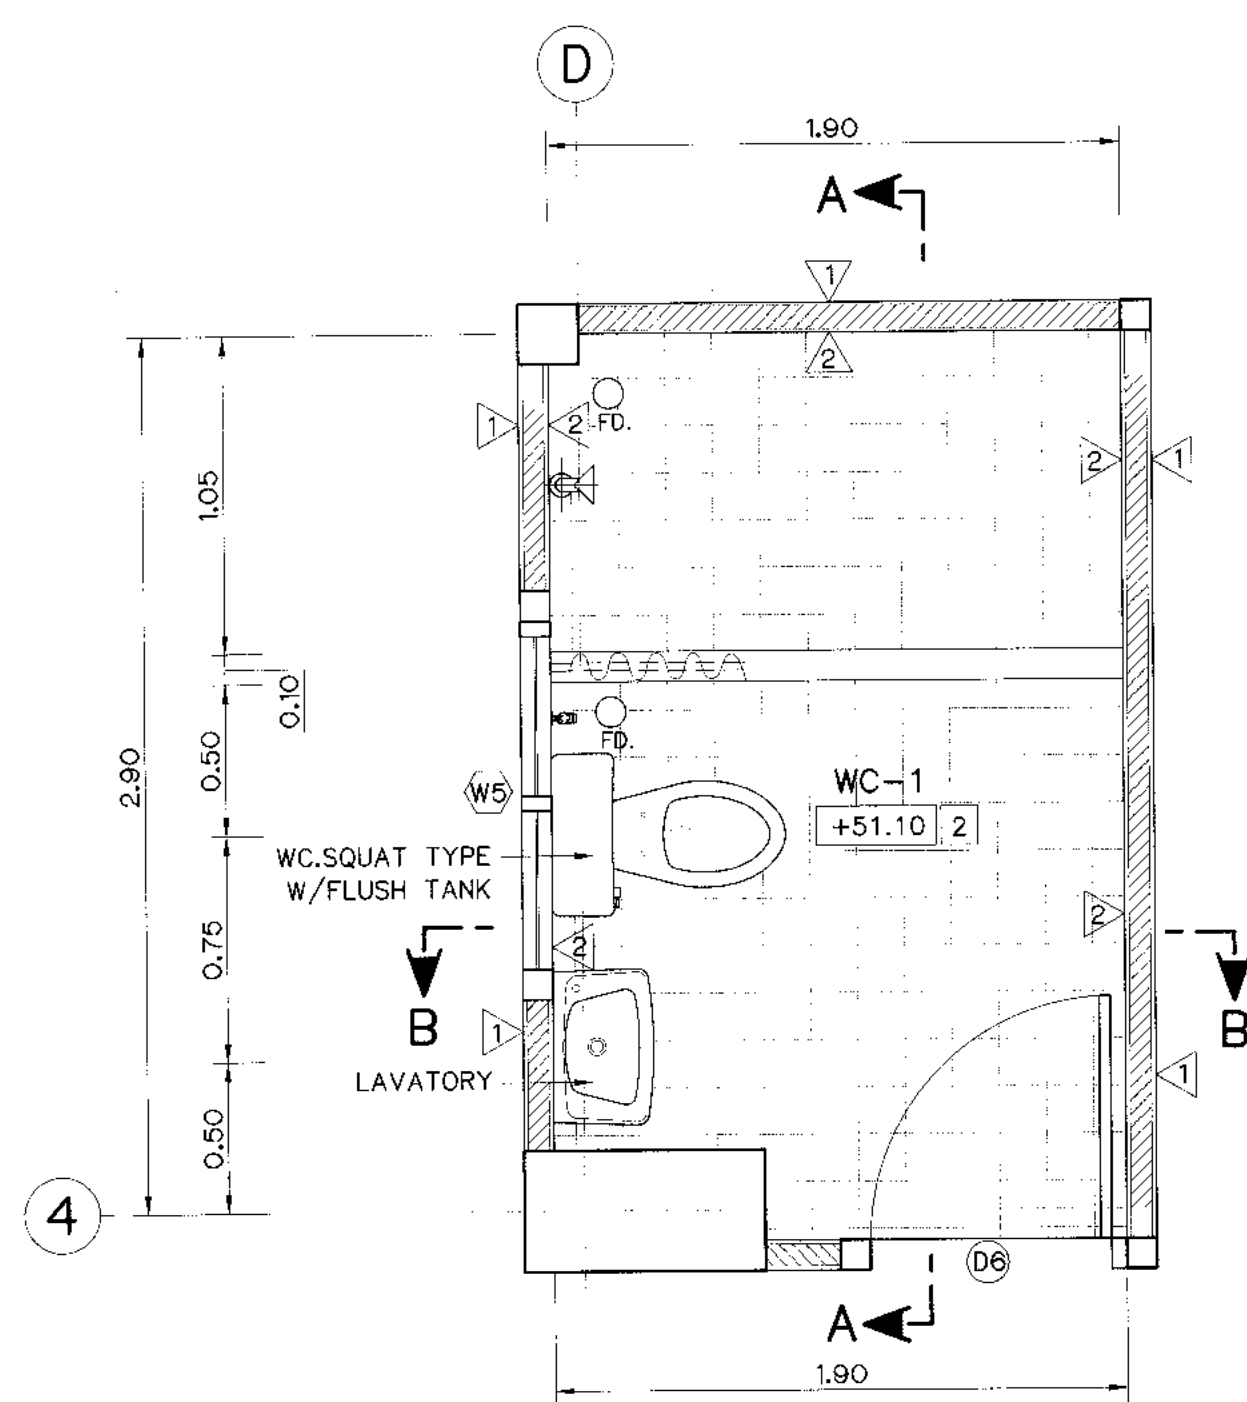


PLAN WC-1
SCALE 1:25

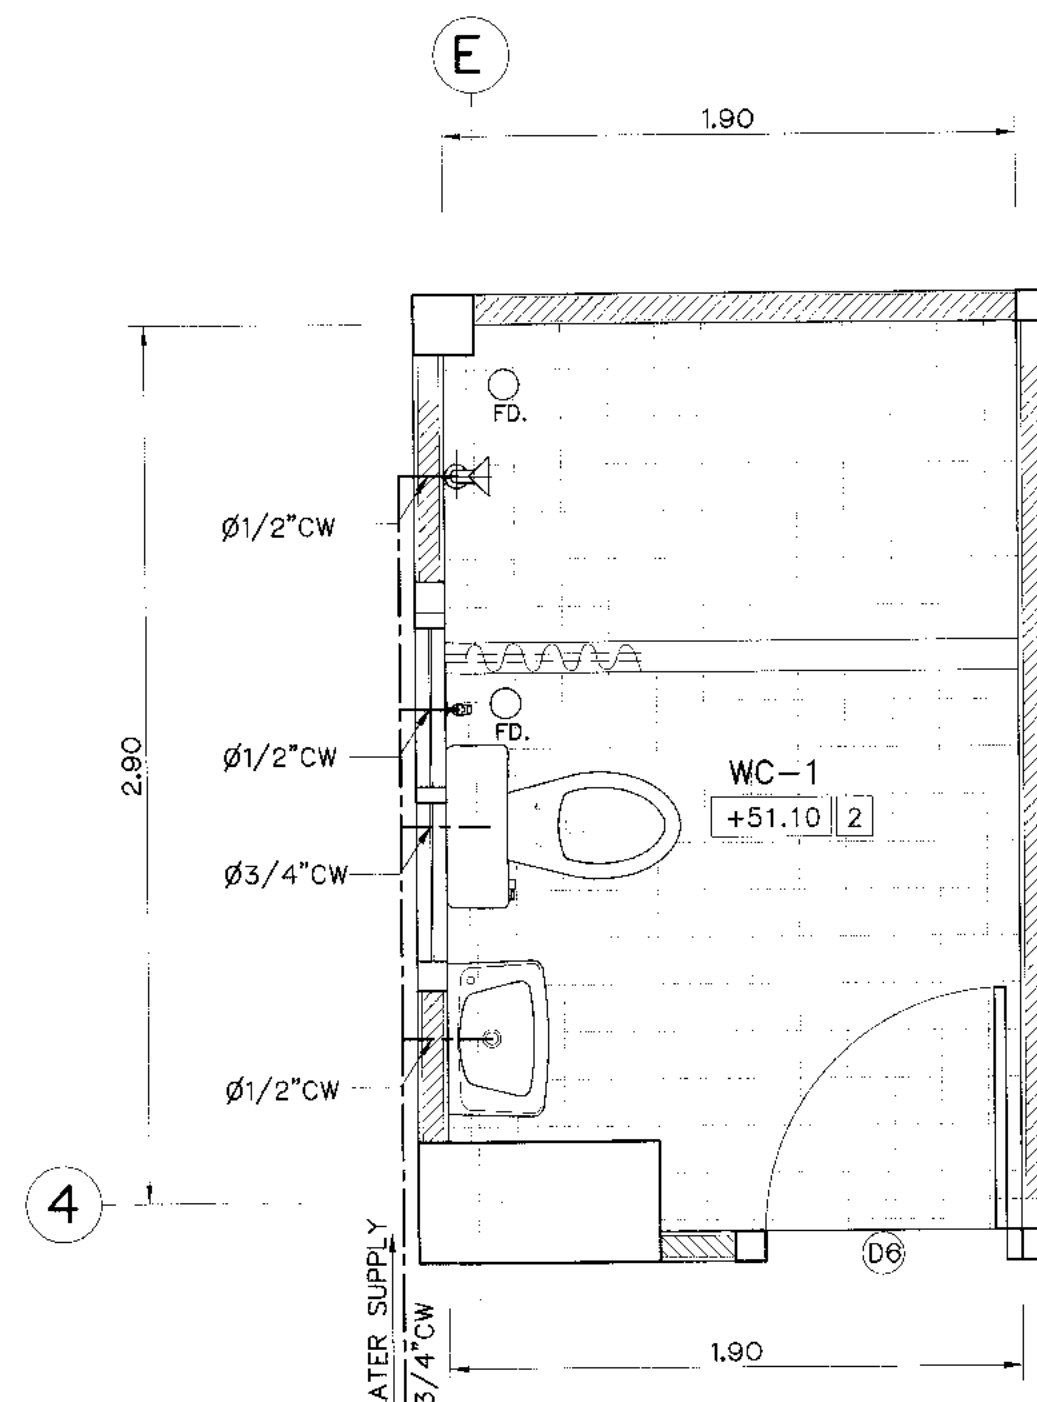


COLD WATER PIPING
SCALE 1:25

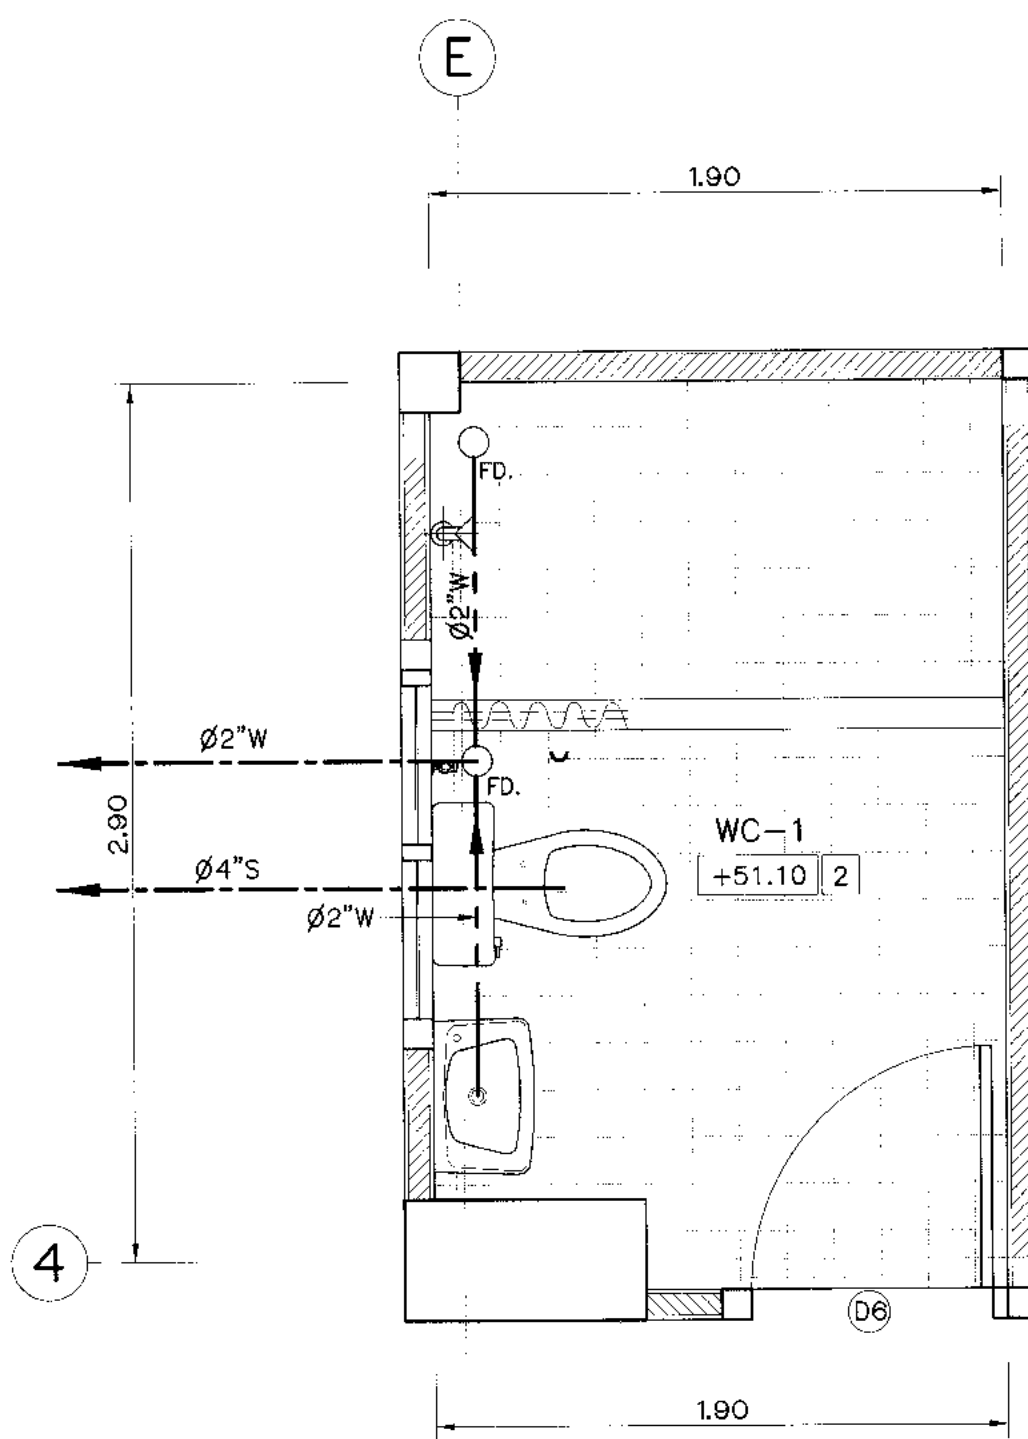


SOIL, WASTE AND VENT PIPING
SCALE 1:25

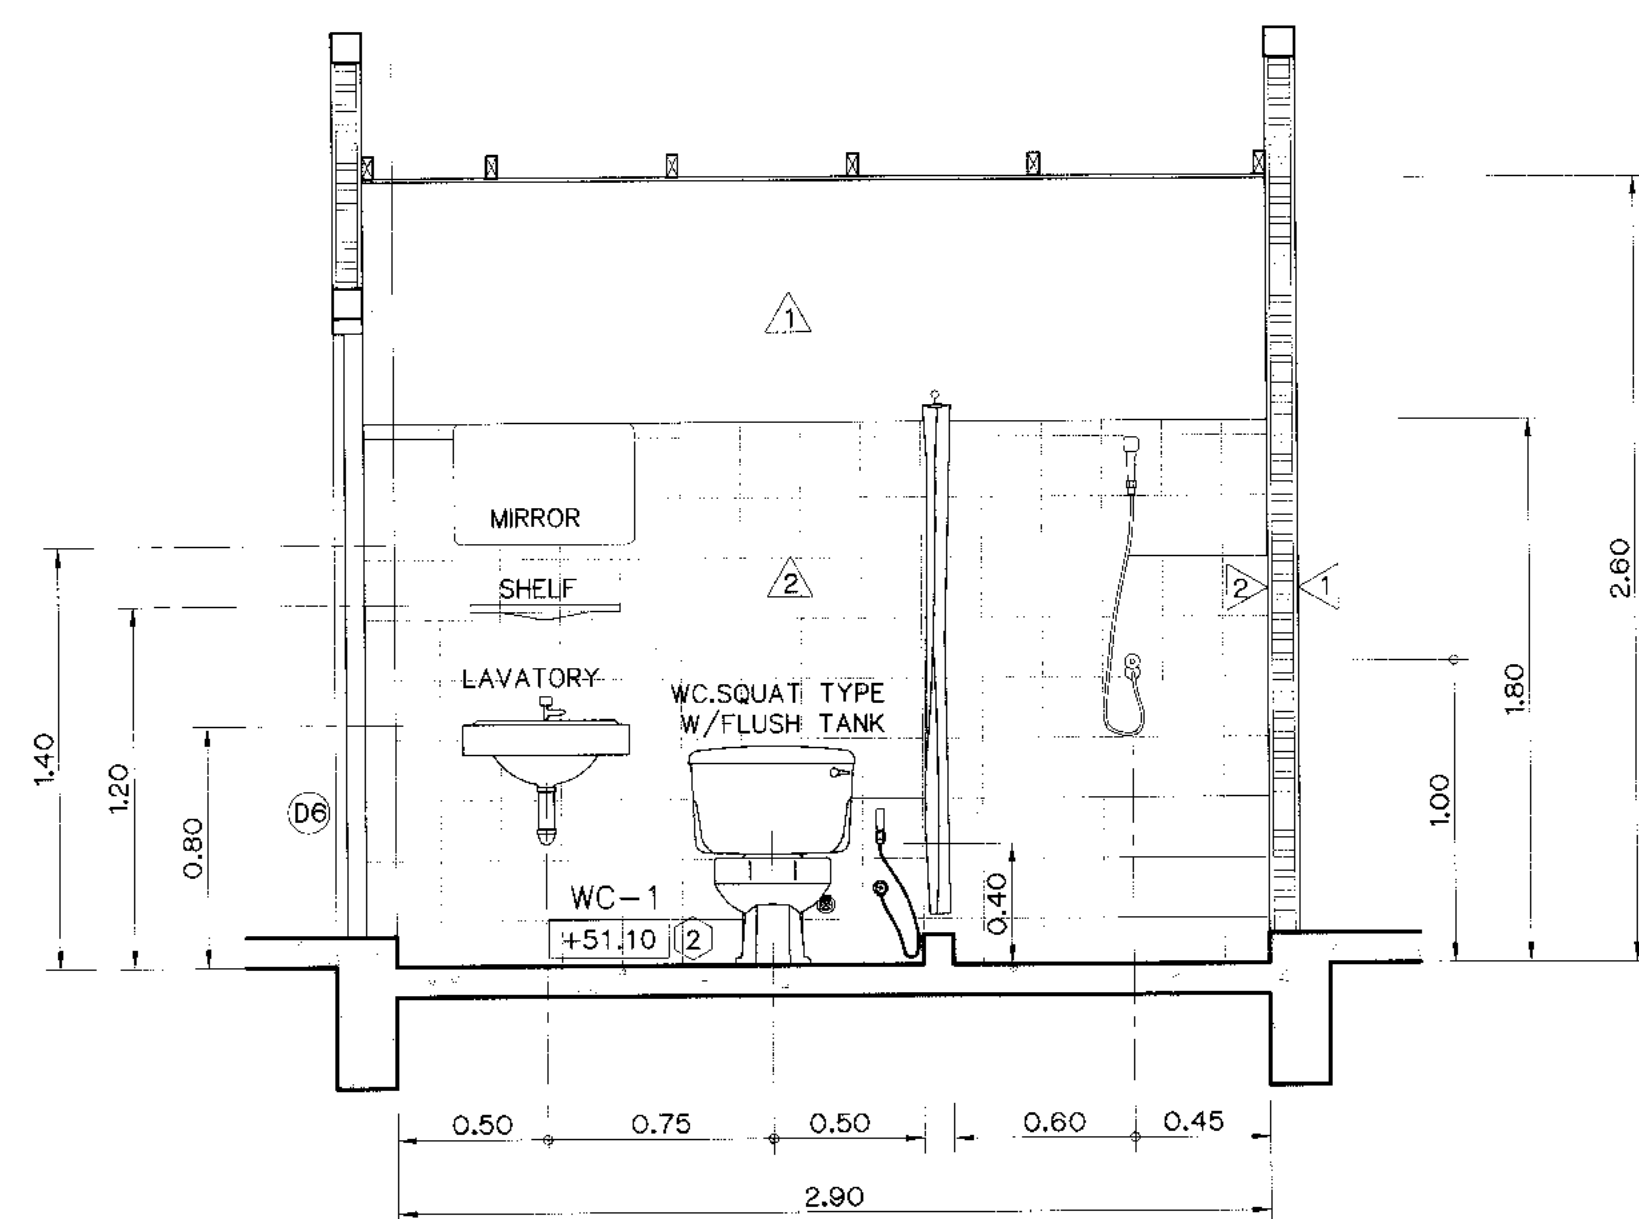


SECTION A-A
SCALE 1:25

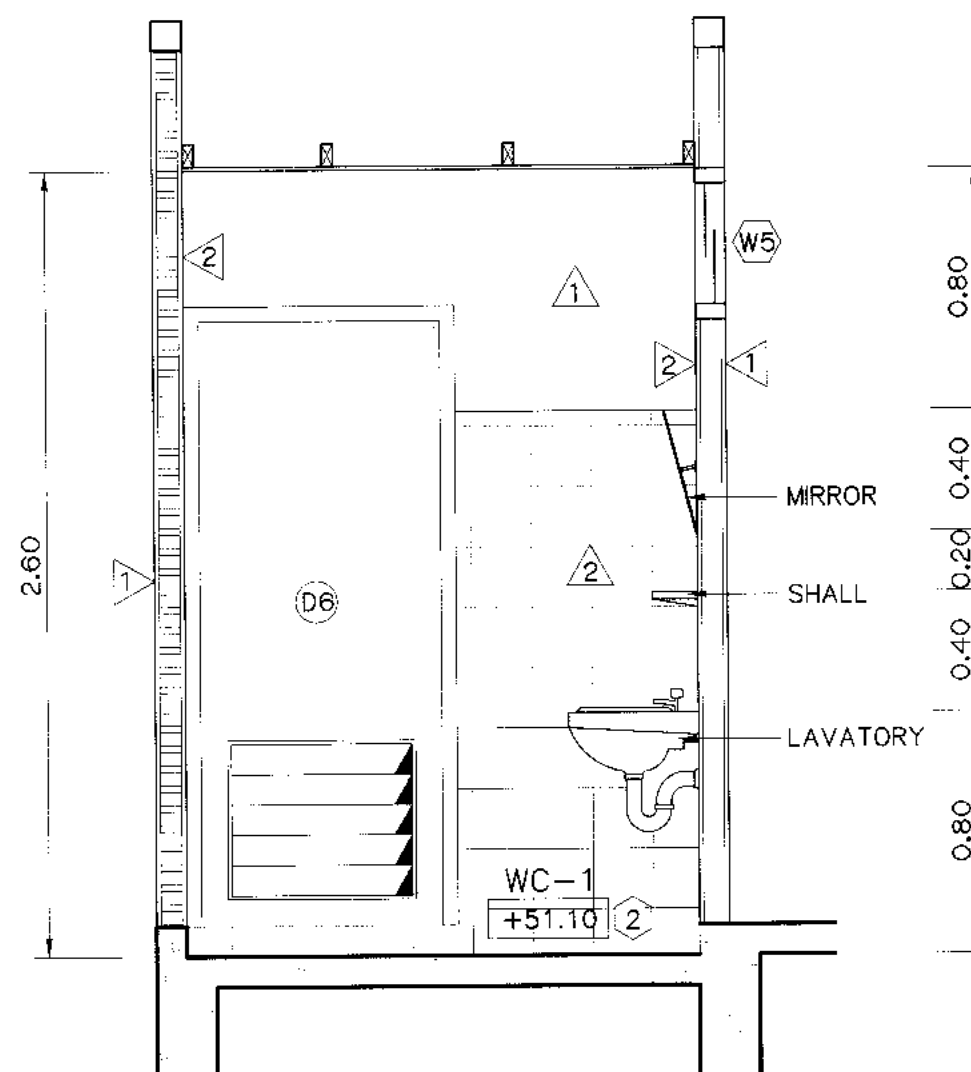


SECTION B-B
SCALE 1:25

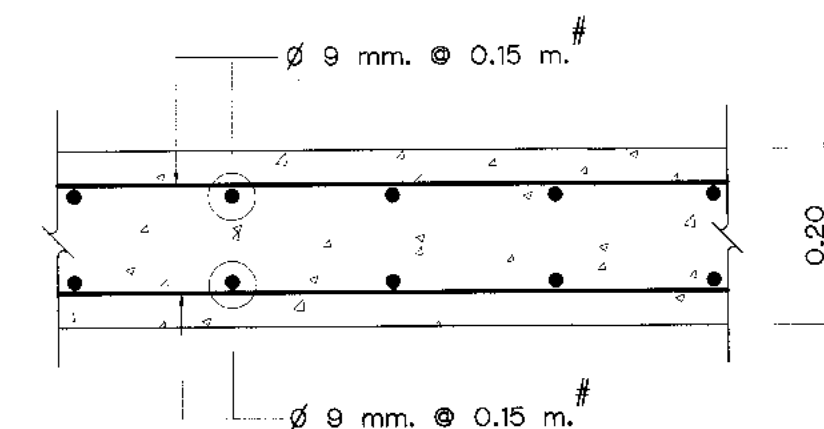

REINFORCEMENT OF BASE SLAB
NOT TO SCALE

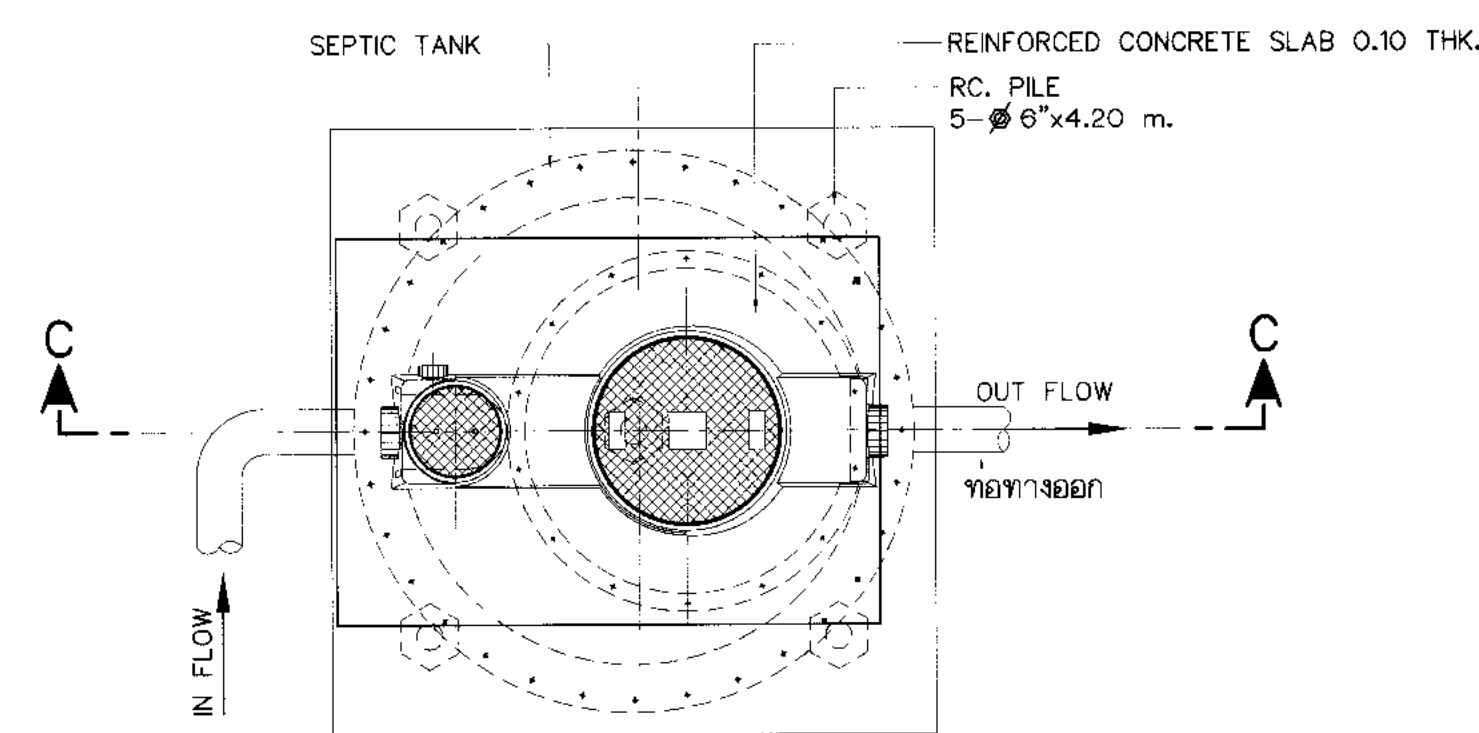

PLAN OF SEPTIC TANK
NOT TO SCALE

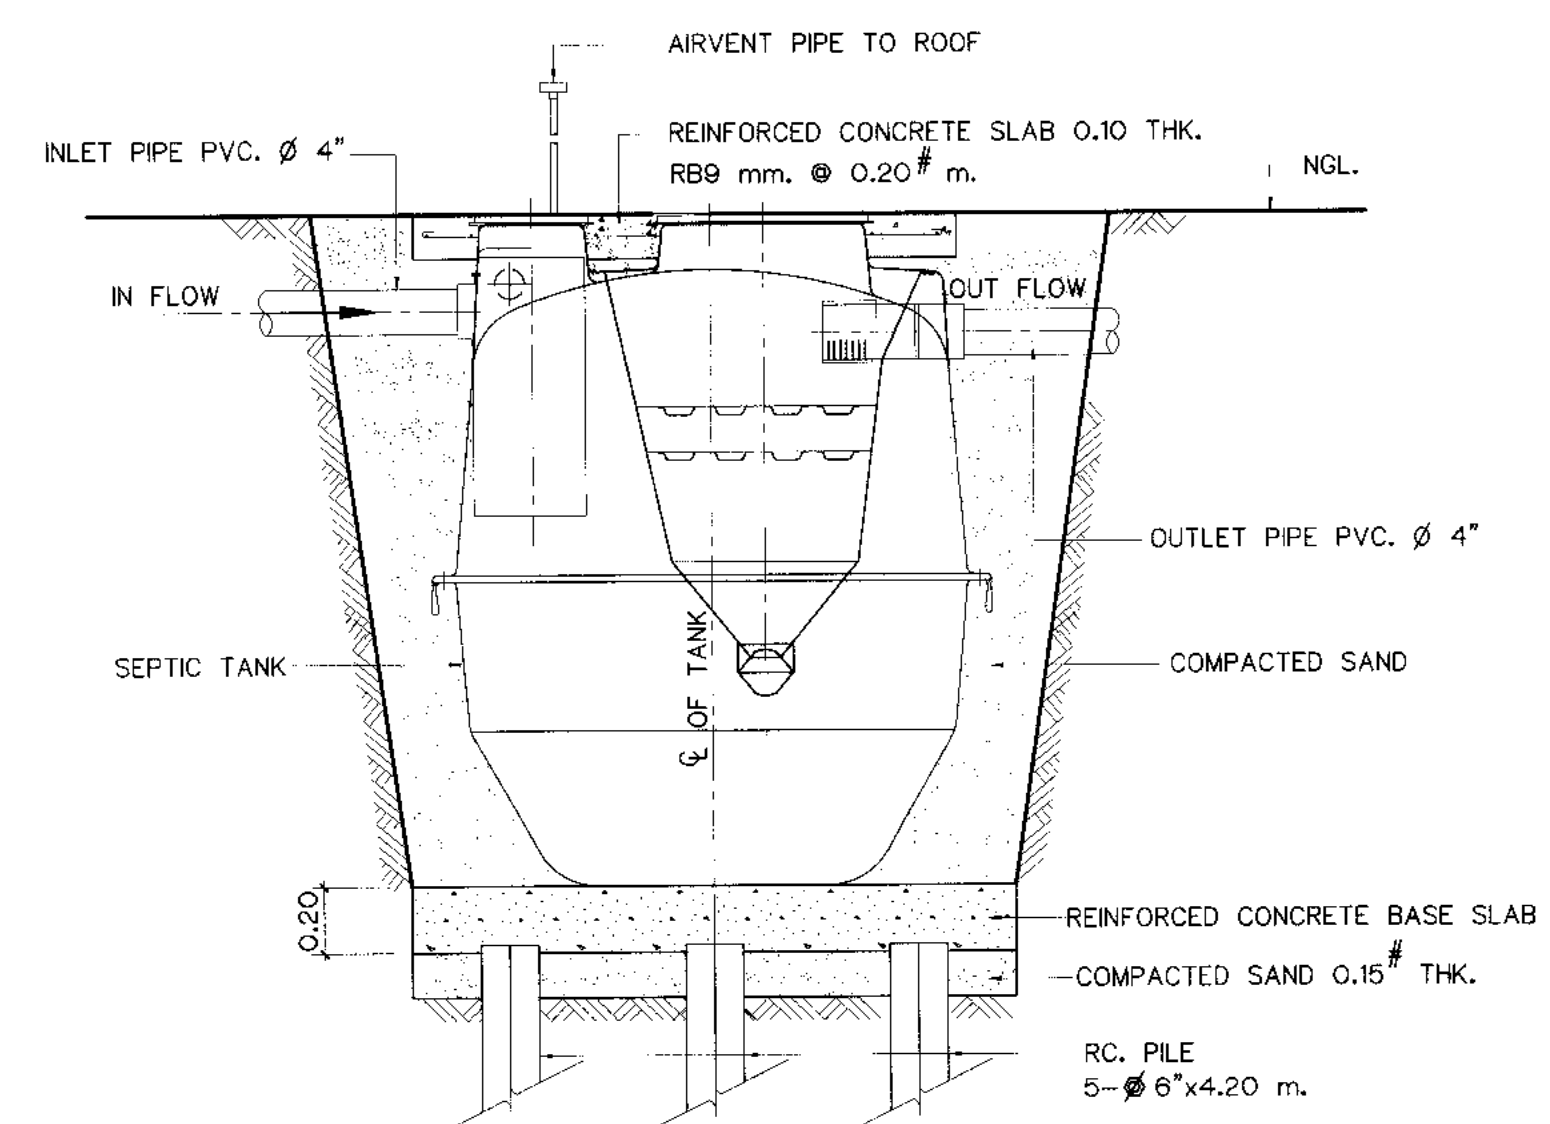

SECTION C-C
NOT TO SCALE

SYMBOLS :

- SOIL PIPE
- — — WASTE PIPE
- — — COLD WATER PIPE
- — — VENT PIPE

NOTES :

- ALL DIMENSIONS AND ELEVATIONS (M.S.L.) ARE IN METERS, UNLESS OTHERWISE SHOWN.
- SYMBOLS, ABBREVIATIONS AND GENERAL NOTES SEE DWG. NO. KLP-GN-03


REFERENCE DRAWING :

- POWERHOUSE, PLAN 1st FLOOR KLP-PH-02




APPLICATION AND DIMENSION OF SEPTIC TANK			
NO. OF USER	VOLUMN		CONDITION
	RESIDENTIAL	SOIL ONLY 60 LPCD TOTAL WASTE 200 LPCD	
			18 5

REMARK: LPCD = LITER PER CAPITAL PER DAY

MATERIAL AND APPLICATION OF SEPTIC TANK	
COMPONENTS	MATERIAL
1. TANK BODY	LLDEL (LINER LOW TYPE MEDIUM DENSITY)
2. MANHOLE COVER	ABS (ACRYLONITRILE-BUTADIENE-STYRENE), IRON CAST
3. INLET, OUTLET PIPES	POLYETHYLENE
4. FLEX	FLEXIBLE FITTING ABS Ø 100 MM.
5. MEDIA	HDPE

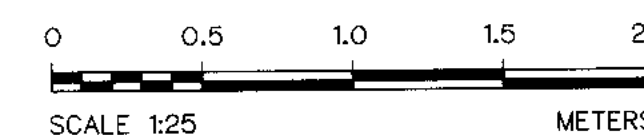

KINGDOM OF THAILAND Department of Alternative Energy Development and Efficiency MINISTRY OF ENERGY	
KLONG LAM PLOK HYDROPOWER PROJECT	
CIVIL WORKS AND TRANSMISSION LINE POWERHOUSE DETAILS OF TOILET, AND BUCKET TREATS	
DESIGNED <i>[Signature]</i> 28/29074 DRAWN <i>[Signature]</i> CHECKED <i>[Signature]</i> 28/2228 PROJECT MANAGER	REVIEWED <i>[Signature]</i> SUBMITTED <i>[Signature]</i> RECOMMENDED <i>[Signature]</i> APPROVED <i>[Signature]</i> 28/2228 DATE 08/03/2559
SHEET NO. 79 OF 110	

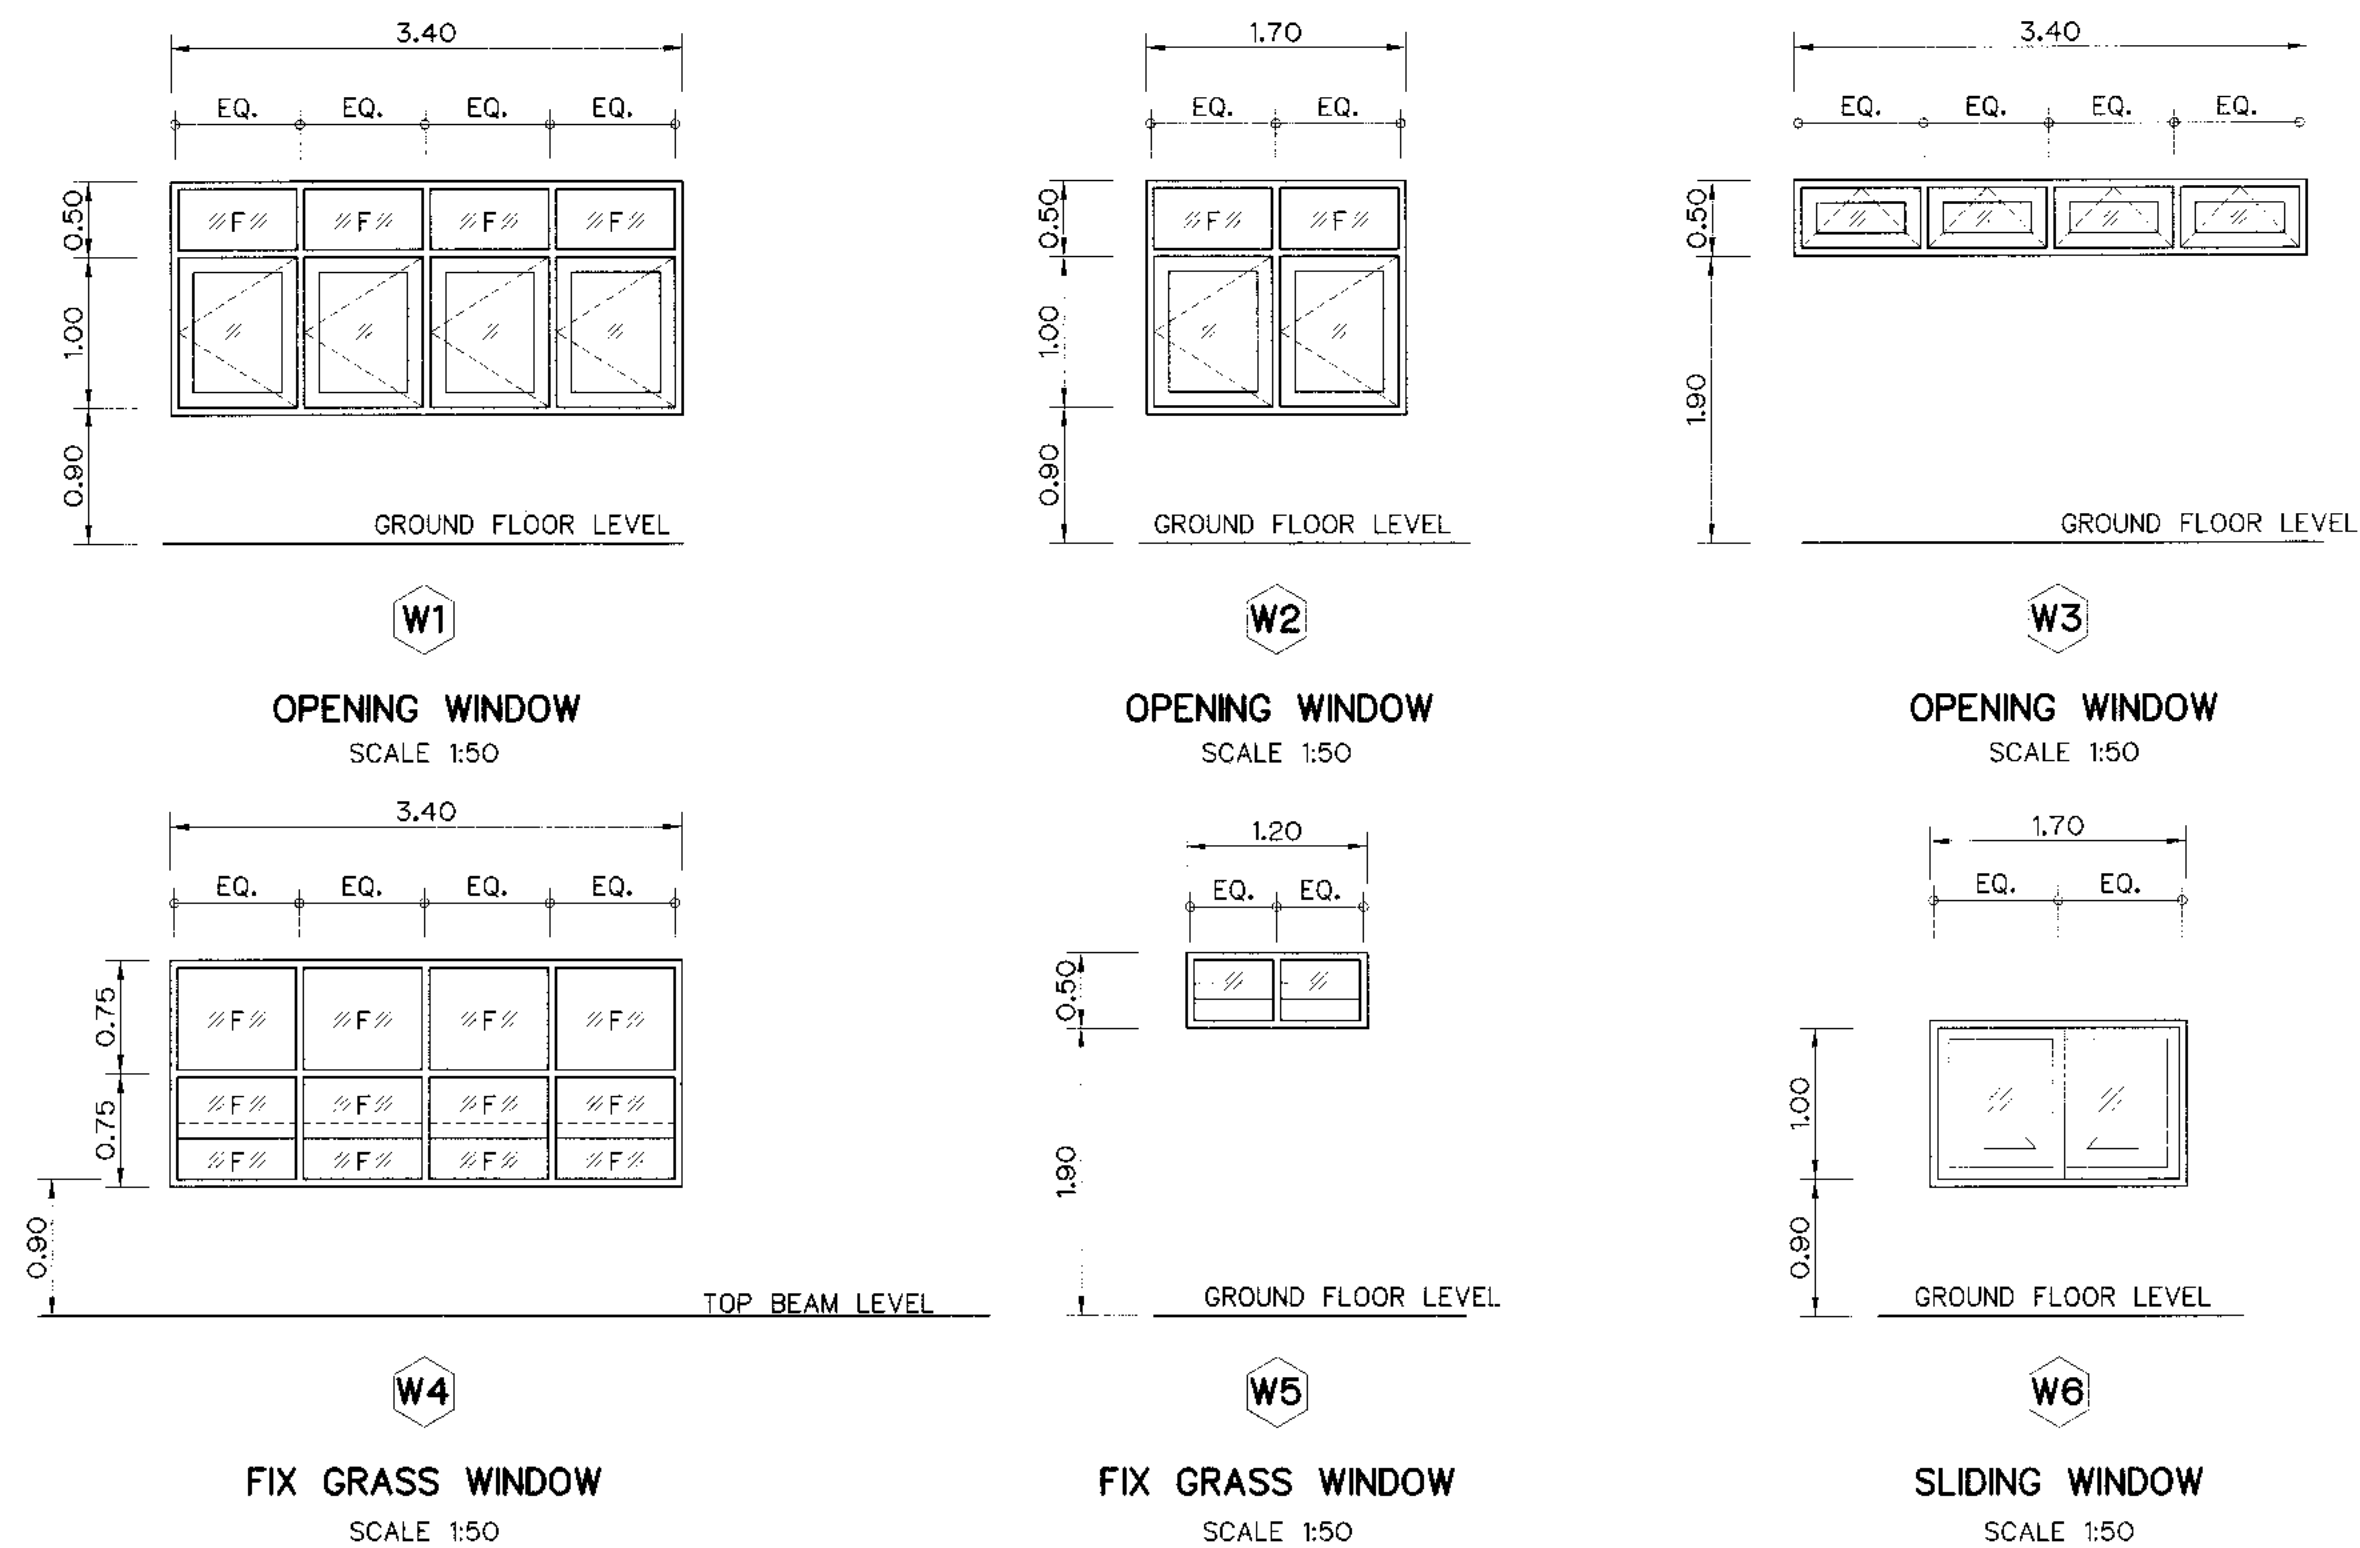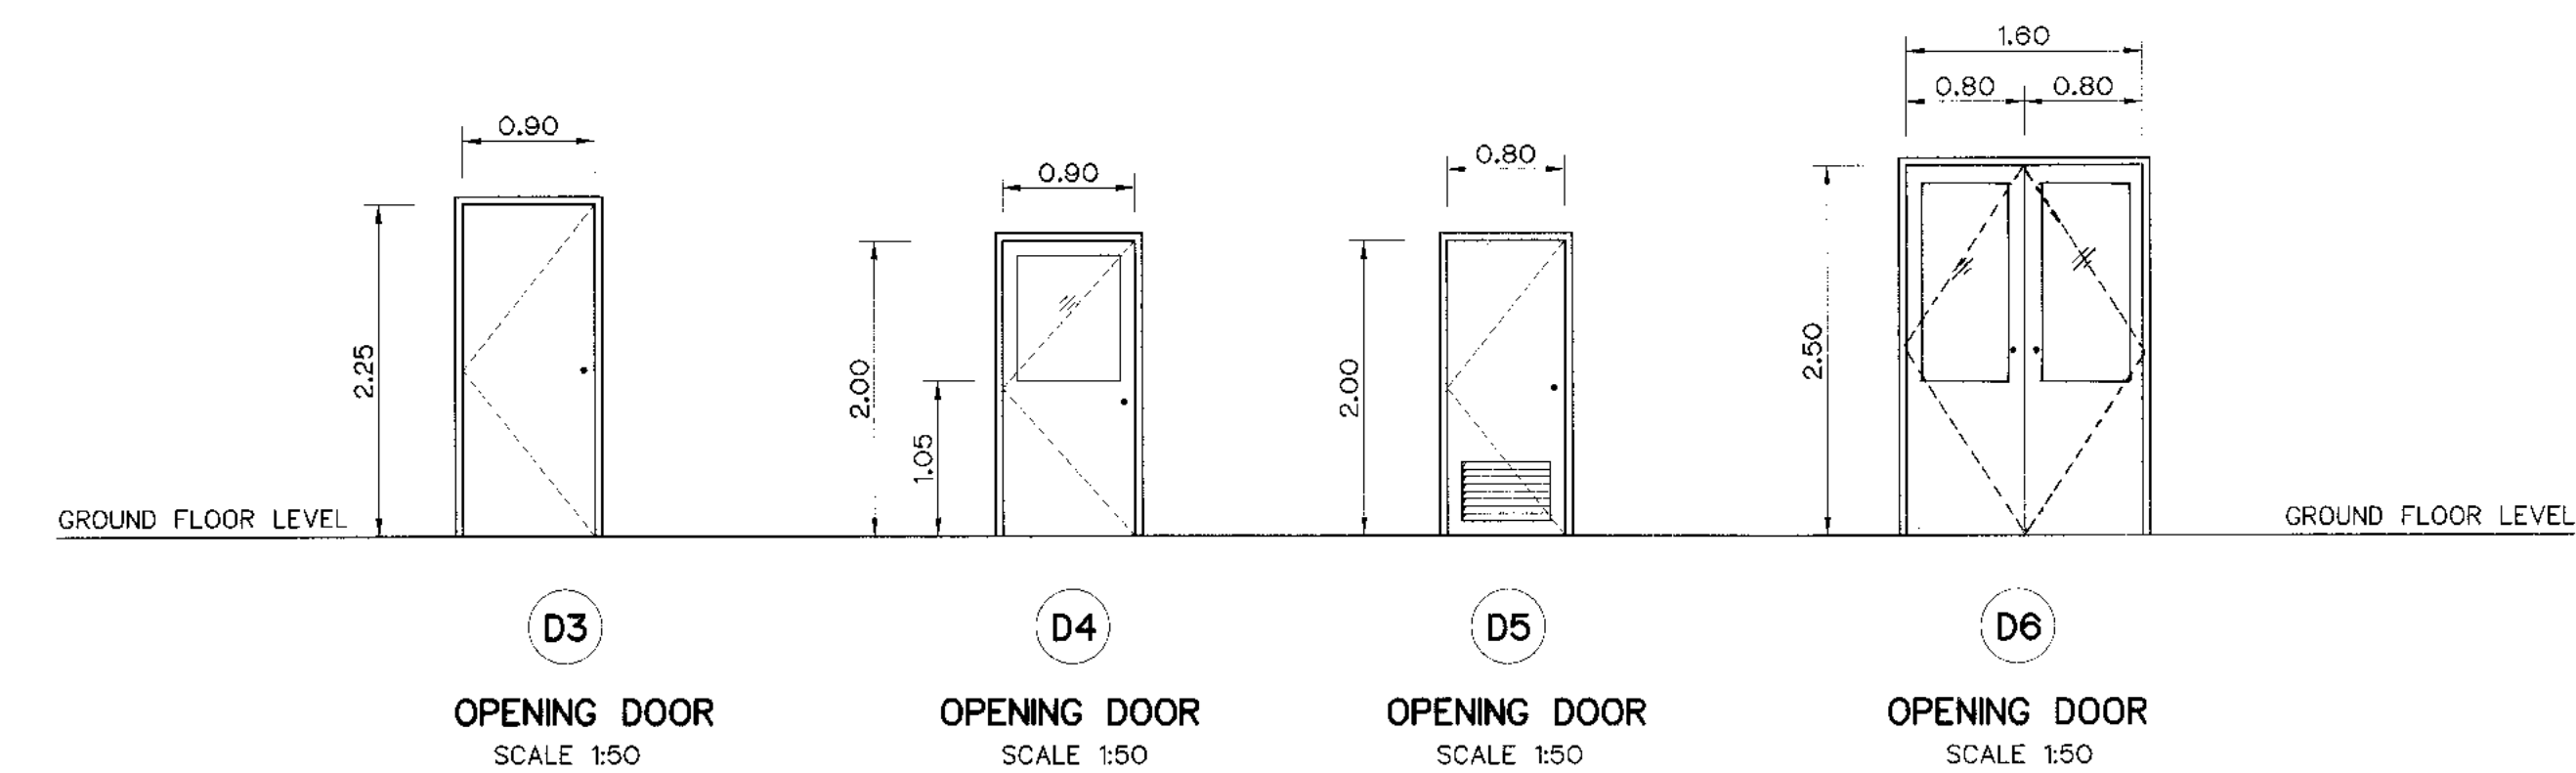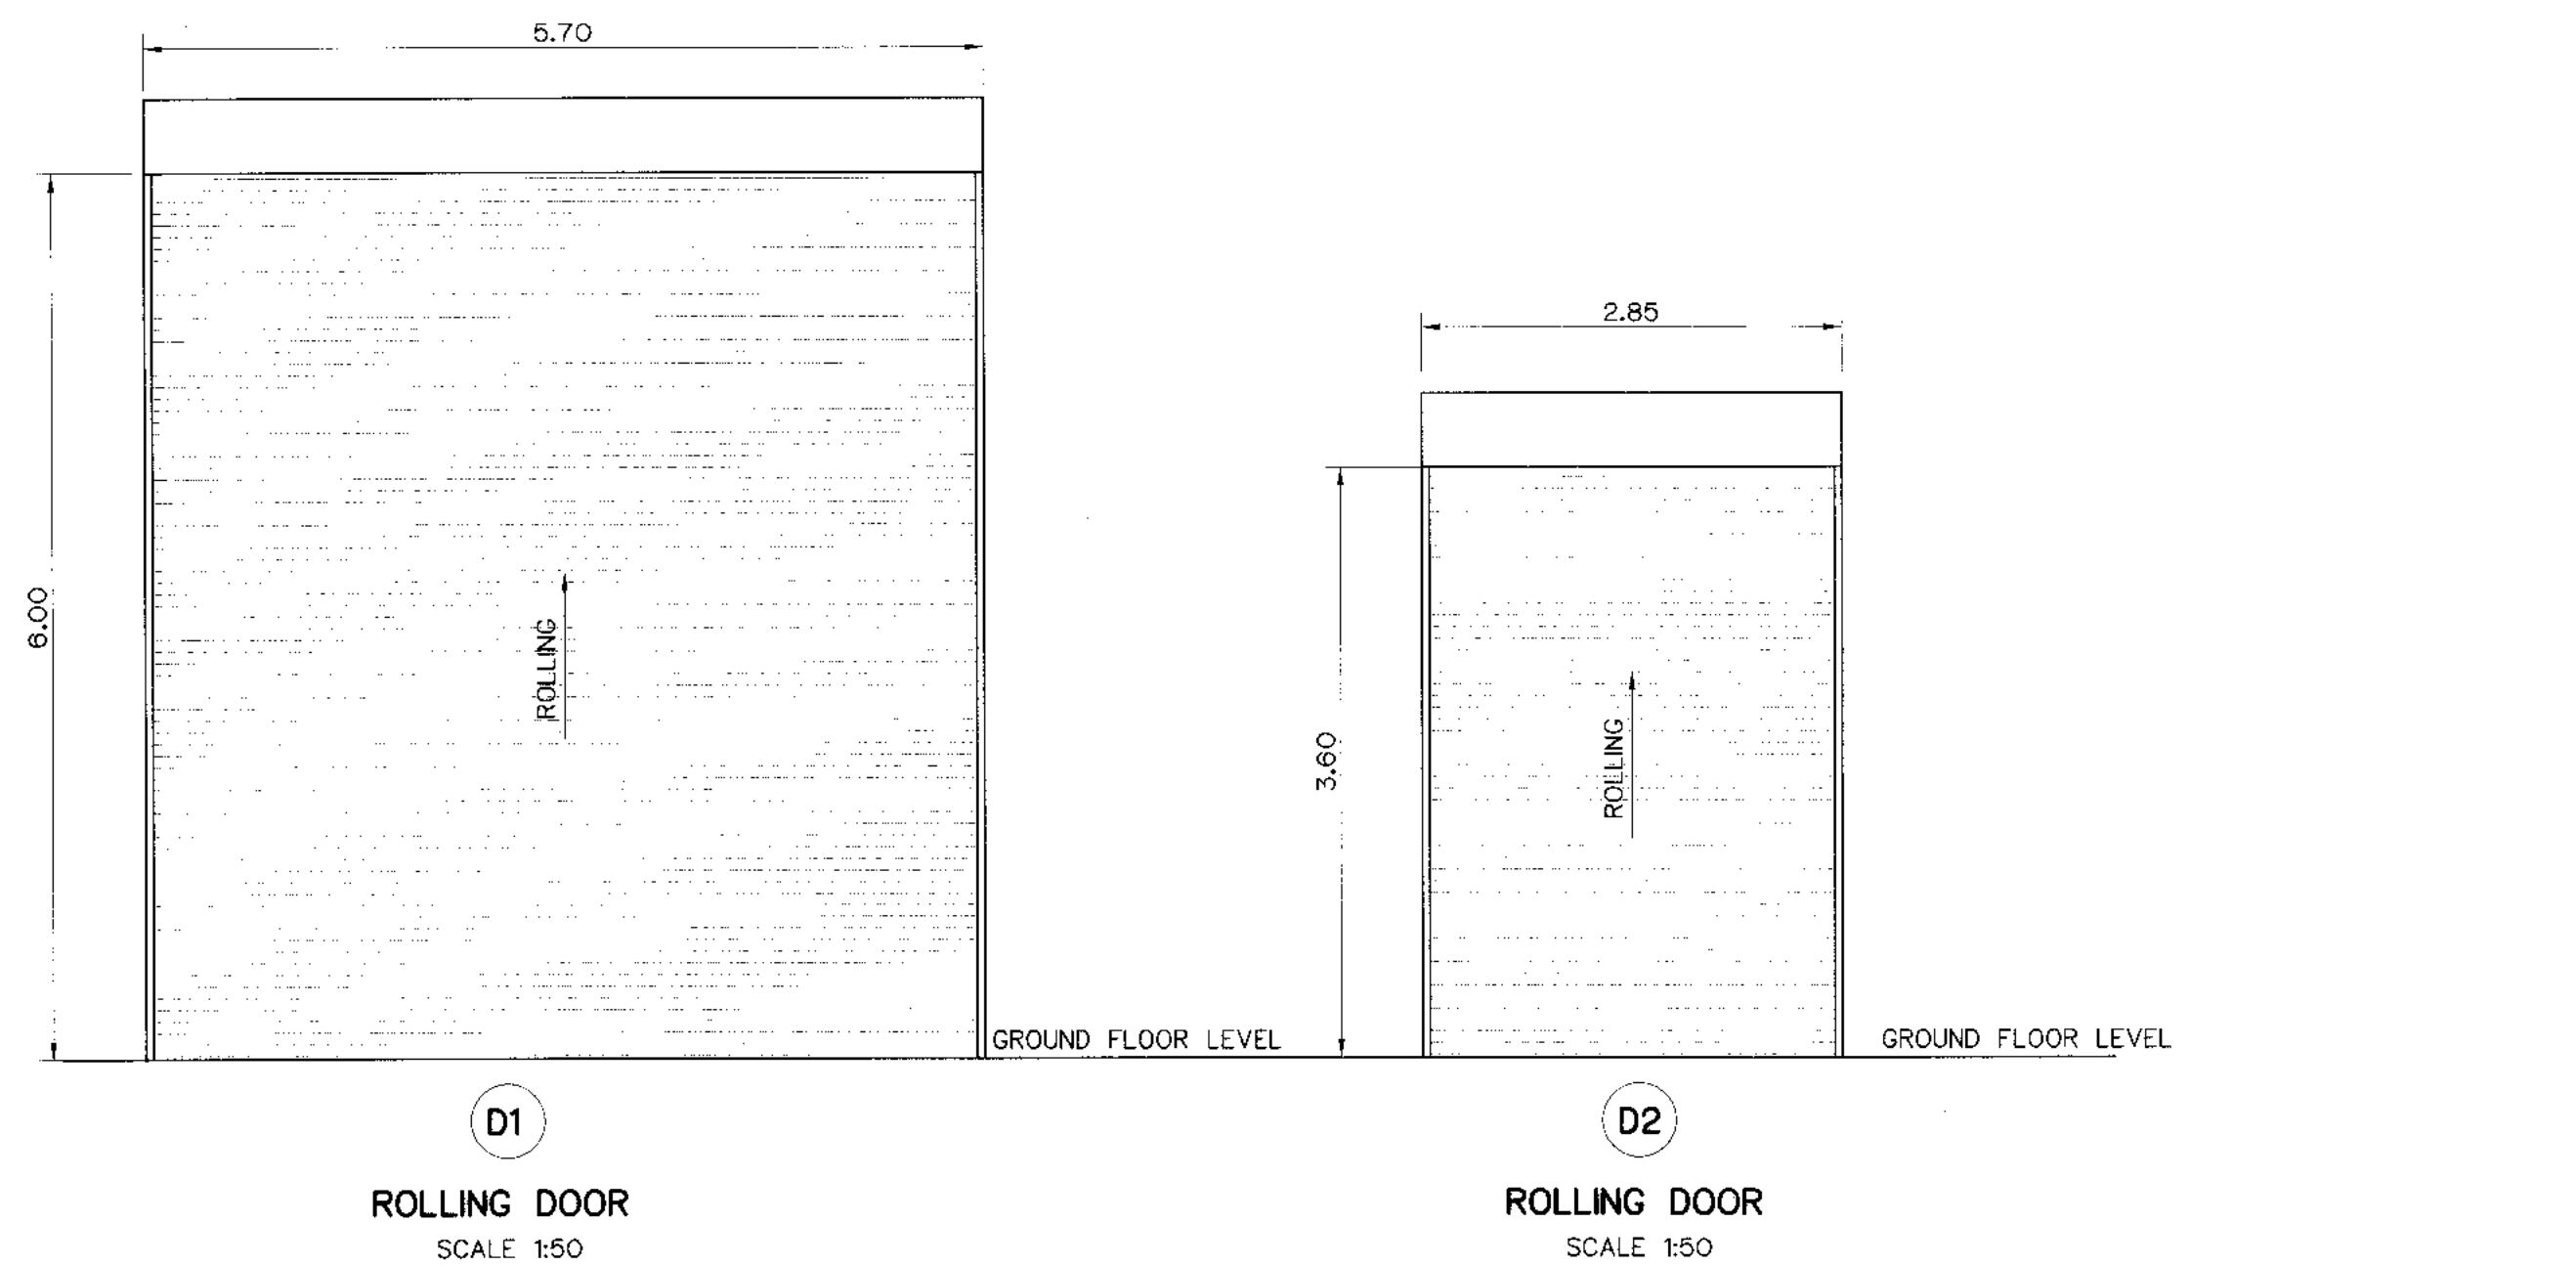


SYMBOL	DESCRIPTIONS	SIZE		FRAME	PANEL	HINGE	LOCKSET	HANDLE	REMARKS
		WIDTH	HEIGHT						
D1	ROLLING DOOR (STEEL NO.18,1.2 mm. Thk.)	5.70	6.00	GALVANIZED STEEL	---	---	NORMAL KEY	---	MOTOR OPERATING
D2	ROLLING DOOR (STEEL NO.18,1.2 mm. Thk.)	2.85	3.60	GALVANIZED STEEL	---	---	NORMAL KEY	---	MOTOR OPERATING
D3	OPENING DOOR	0.90	2.25	HARDWOOD 2"x 4"	TEAK PLYWOOD	STAINLESS STEEL 4"x3"x2.5mm.	CYINDER LOCK	---	
D4	OPENING DOOR	0.90	2.00	HARDWOOD 2"x 4"	TEAK PLYWOOD & GLASS 5 mm.thk.	STAINLESS STEEL 4"x3"x2.5mm.	CYINDER LOCK	---	
D5	OPENING DOOR	0.80	2.00	P.V.C. 2"x 4"	P.V.C.	STAINLESS STEEL 4"x3"x2.5mm.	CYINDER LOCK	---	
D6	OPENING DOOR	1.80	2.50	HARDWOOD 2"x 4"	TEAK PLYWOOD & GLASS 5 mm.thk.	STAINLESS STEEL 4"x3"x2.5 mm.	CYINDER LOCK	---	
W1	OPENING WINDOW	3.40	1.50	ALUMINIUM(NA) 2"x 4"	GLASS 5 mm.thk.	●	●	●	FULL SET OF ACCESSORIES FROM MANUFACTURER
W2	OPENING WINDOW	1.70	1.50	ALUMINIUM(NA) 2"x 4"	GLASS 5 mm.thk.	●	●	●	FULL SET OF ACCESSORIES FROM MANUFACTURER
W3	OPENING WINDOW	3.40	0.50	ALUMINIUM(NA) 2"x 4"	GLASS 5 mm.thk.	●	●	●	FULL SET OF ACCESSORIES FROM MANUFACTURER
W4	FIXED GLASS WINDOW	3.40	1.50	ALUMINIUM(NA) 2"x 4"	GLASS 5 mm.thk.	---	---	---	
W5	FIXED GLASS WINDOW	1.20	0.50	ALUMINIUM(NA) 2"x 4"	GLASS 5 mm.thk.	---	---	---	
W6	SLIDING WINDOW	1.70	1.00	ALUMINIUM(NA) 2"x 4"	GLASS 5 mm.thk.	---	---	---	
W7	SLIDING WINDOW	3.35	1.00	ALUMINIUM(NA) 2"x 4"	GLASS 5 mm.thk.	---	●	●	FULL SET OF ACCESSORIES FROM MANUFACTURER
●	SHALL BE USED SPECIFIED ACCESSORIES								

NOTES :

- ALL DIMENSIONS AND ELEVATIONS (M.S.L.) ARE IN METERS, UNLESS OTHERWISE SHOWN.
- SYMBOLS, ABBREVIATIONS AND GENERAL NOTES SEE DWG. NO. KLP-GN-03
- FOR PAINTING WORKS SEE TECHNICAL SPECIFICATION




REFERENCE DRAWINGS :

- POWERHOUSE, PLAN 1st FLOOR KLP-PH-02
- POWERHOUSE, ELEVATIONS KLP-PH-04
- POWERHOUSE, SECTIONS (SHEET 1/2) KLP-PH-05
- POWERHOUSE, SECTIONS (SHEET 2/2) KLP-PH-06

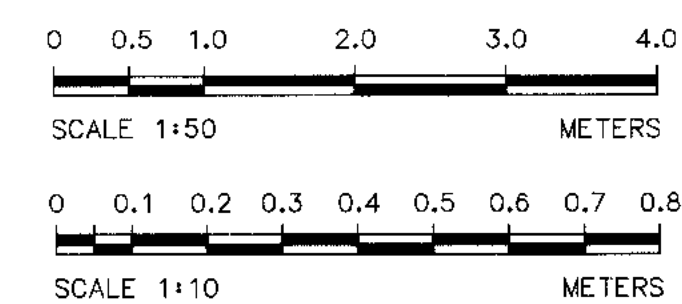


3				
2				
1				
NO.	DATE	REVISIONS	CHECKED	APPROVED
			CONSULTANTS	DEDE

KINGDOM OF THAILAND Department of Alternative Energy Development and Efficiency MINISTRY OF ENERGY	
KLONG LAM PLOK HYDROPOWER PROJECT	
CIVIL WORKS AND TRANSMISSION LINE POWERHOUSE DETAIL OF DOORS, WINDOWS AND NAME PLATE	
DESIGNED <i>[Signature]</i> 251.29074 DRAWN <i>[Signature]</i> CHECKED <i>[Signature]</i> 251.8226 PROJECT MANAGER	REVIEWED <i>[Signature]</i> SUBMITTED <i>[Signature]</i> RECOMMENDED <i>[Signature]</i> APPROVED <i>[Signature]</i> 251.8226 DATE 08/03/2559
P&C MANAGEMENT CO.,LTD.	DEPARTMENT OF ALTERNATIVE ENERGY DEVELOPMENT AND EFFICIENCY MINISTRY OF ENERGY
DRAWING NO. KLP-PH-08	SHEET NO. 80 OF 110

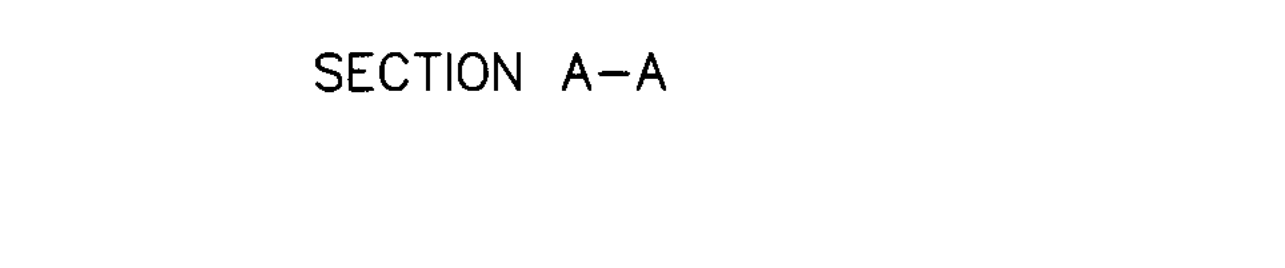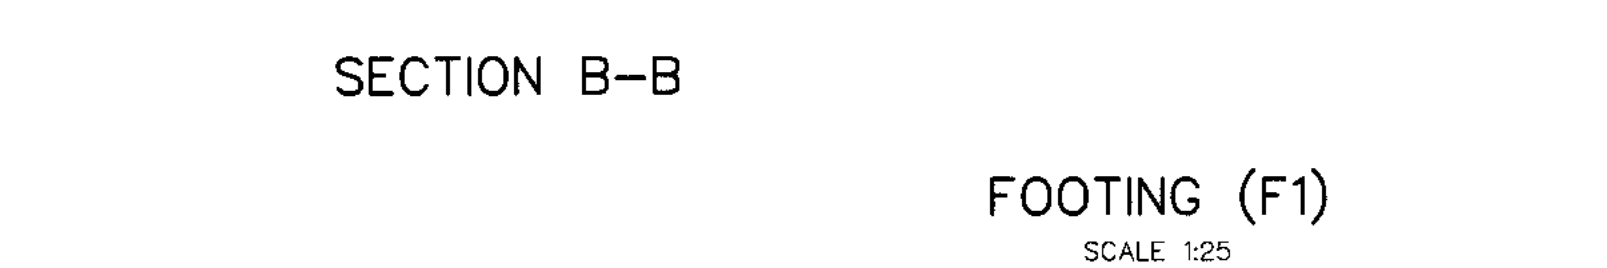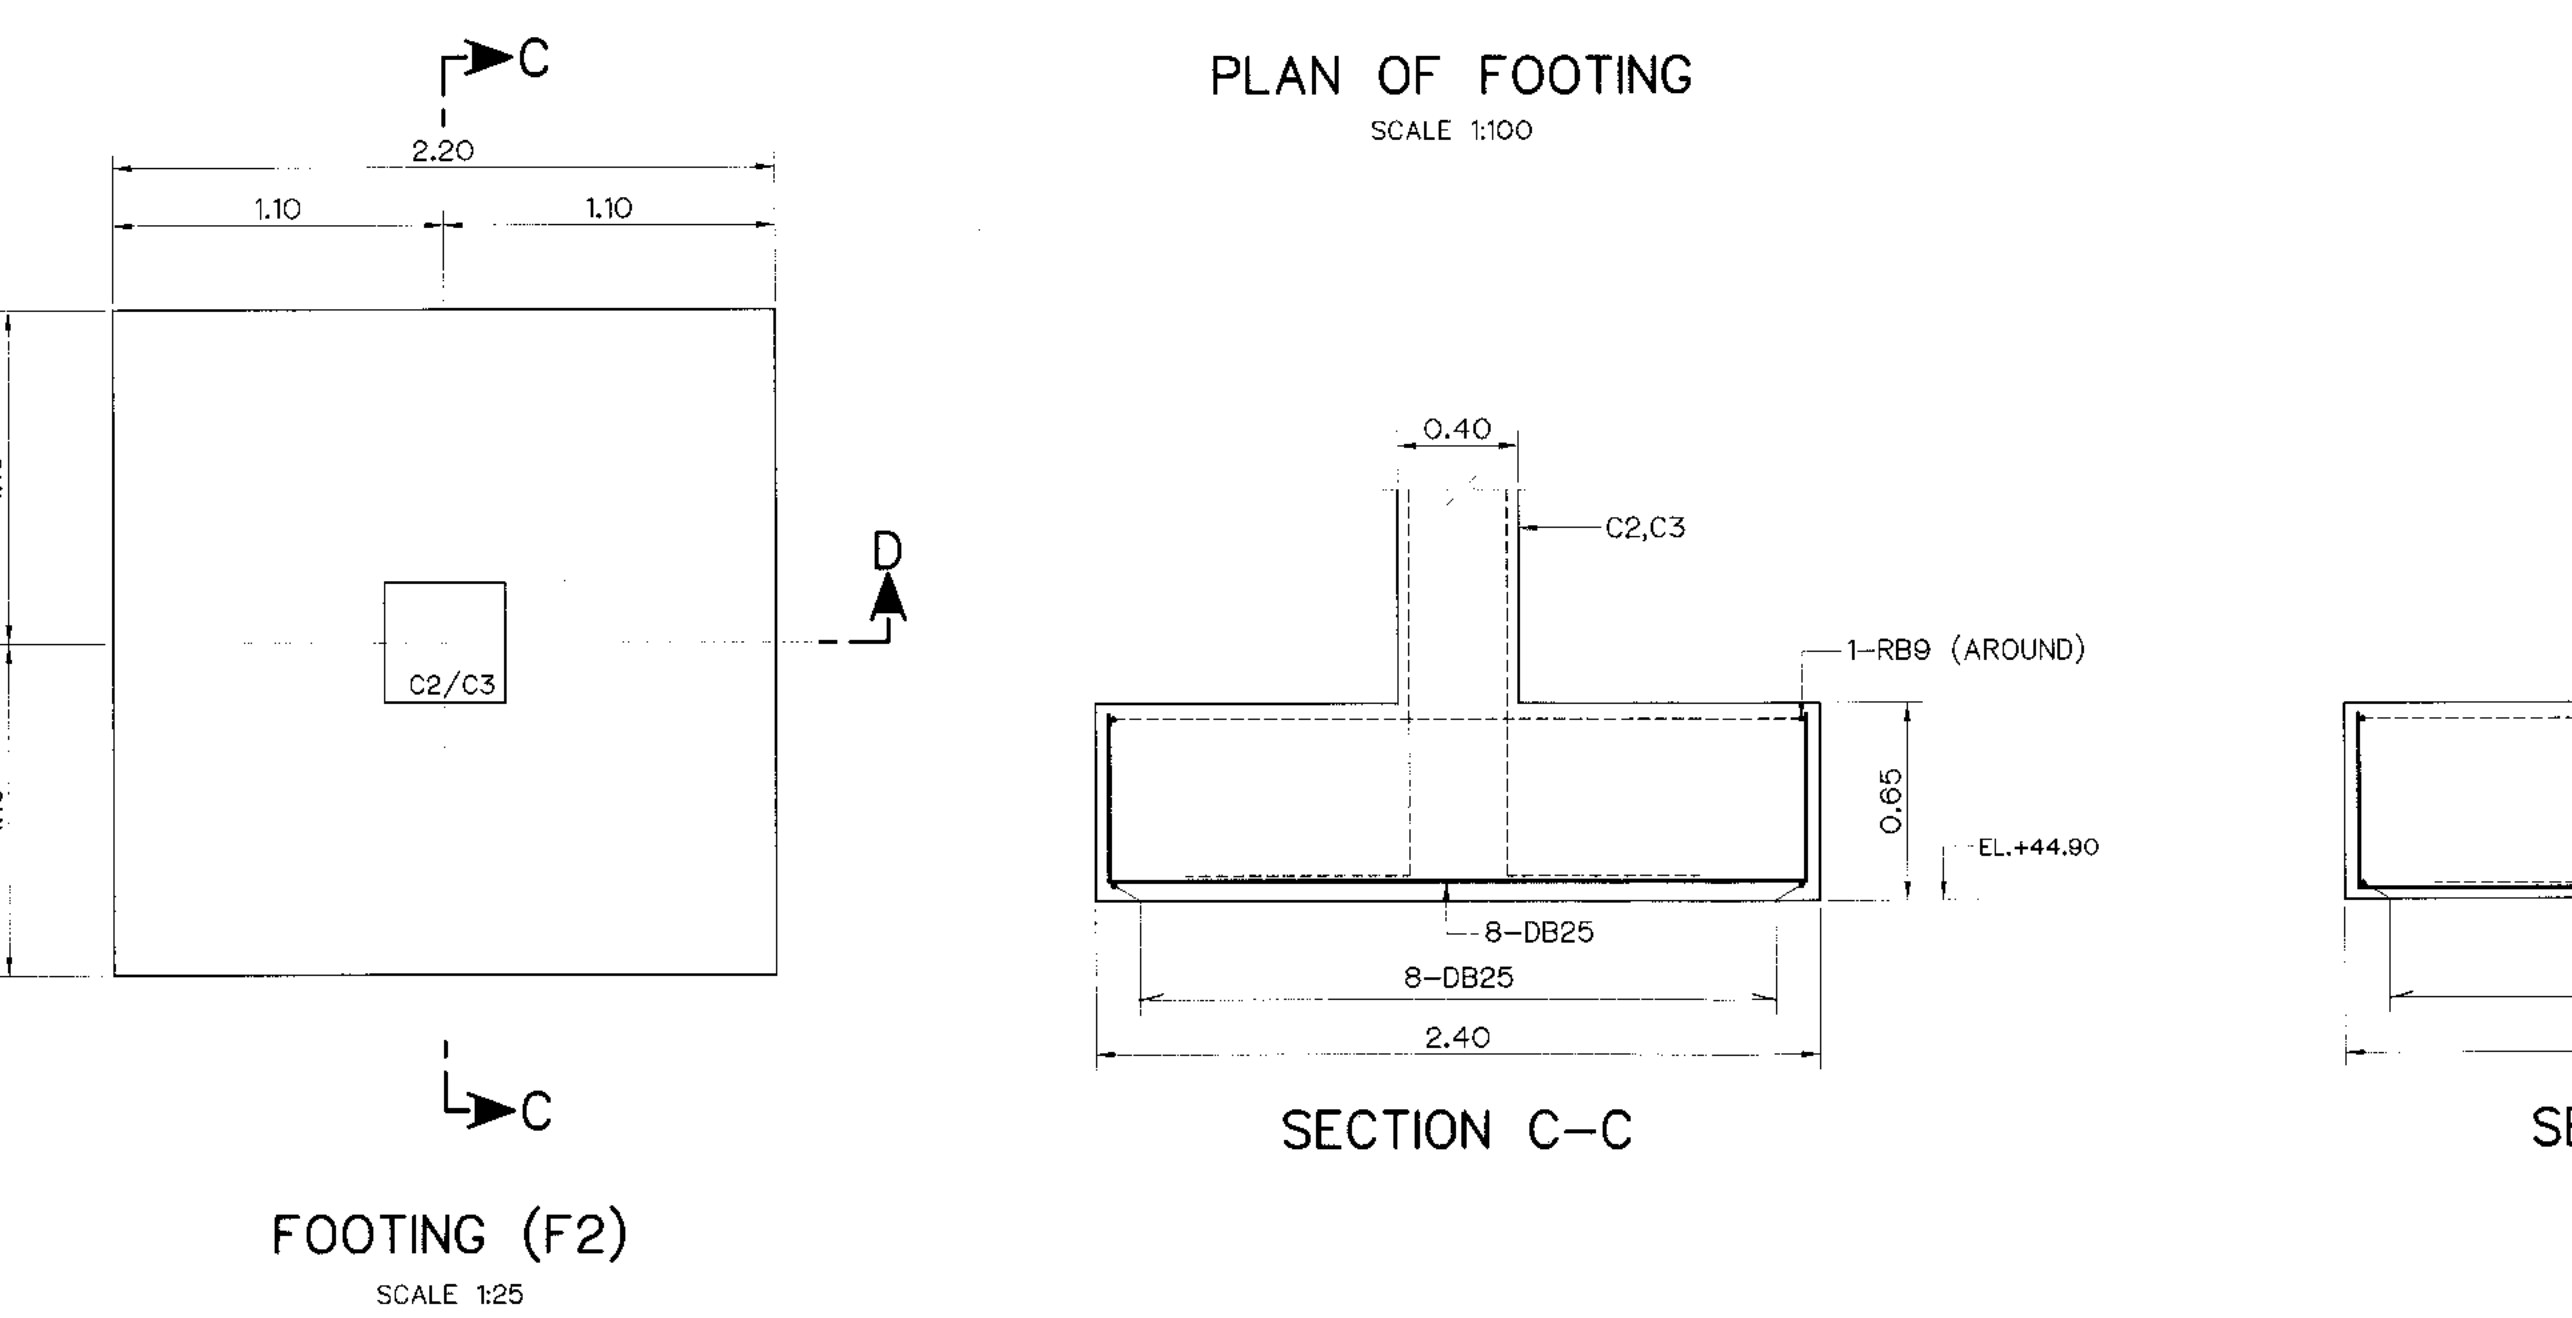




- ### NOTES :
1. ALL DIMENSIONS AND ELEVATIONS (M.S.L.) ARE IN METERS,
UNLESS OTHERWISE SHOWN.
 2. SYMBOLS, ABBREVIATIONS AND GENERAL NOTES SEE DWG. NO. KLP-GN-03
 3. CONCRETE DESIGN BASED ON THE COMPRESSIVE STRENGTH OF 210 KSC,
STANDARD CYLINDER $\phi 0.15 \times 0.30$ m. TEST AT AGE 28 DAYS. UNLESS
OTHERWISE INDICATED IN SPECIFIC DRAWINGS.
 4. ALLOWABLE BEARING CAPACITY OF FOUNDATION SHOULD NOT LESS THAN 20 TON/sq m.

- REFERENCE DRAWINGS :
- | | |
|-------------------------------|-----------|
| 1. POWERHOUSE, PLAN 1st FLOOR | KLP-PH-02 |
|-------------------------------|-----------|

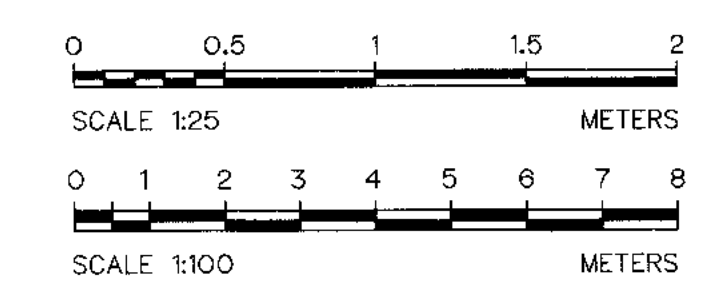

3				
2				
1				
NO.	DATE	REVISIONS	CHECKED	APPROVED
	CONSULTANTS		DEDE	


 KINGDOM OF THAILAND Department of Alternative Energy Development and Efficiency MINISTRY OF ENERGY	
KLONG LAM PLOK HYDROPOWER PROJECT	
CIVIL WORKS AND TRANSMISSION LINE POWERHOUSE PLAN OF FOOTING AND DETAILS	
 P&C MANAGEMENT CO., LTD.	 Department of Alternative Energy Development and Efficiency MINISTRY OF ENERGY
DESIGNED <i>W. 20074</i> <i>07.08.2006</i> DRAWN <i>Ph X</i> CHECKED <i>P.D.</i> <i>08.08.2006</i>	REVIEWED <i>X.S.</i> SUBMITTED <i>Chani</i> RECOMMENDED APPROVED <i>P. Hamsil</i>
<i>OL</i> PROJECT MANAGER	DRAWING NO. KLP-PH-09 SHEET NO. 81 OF 110

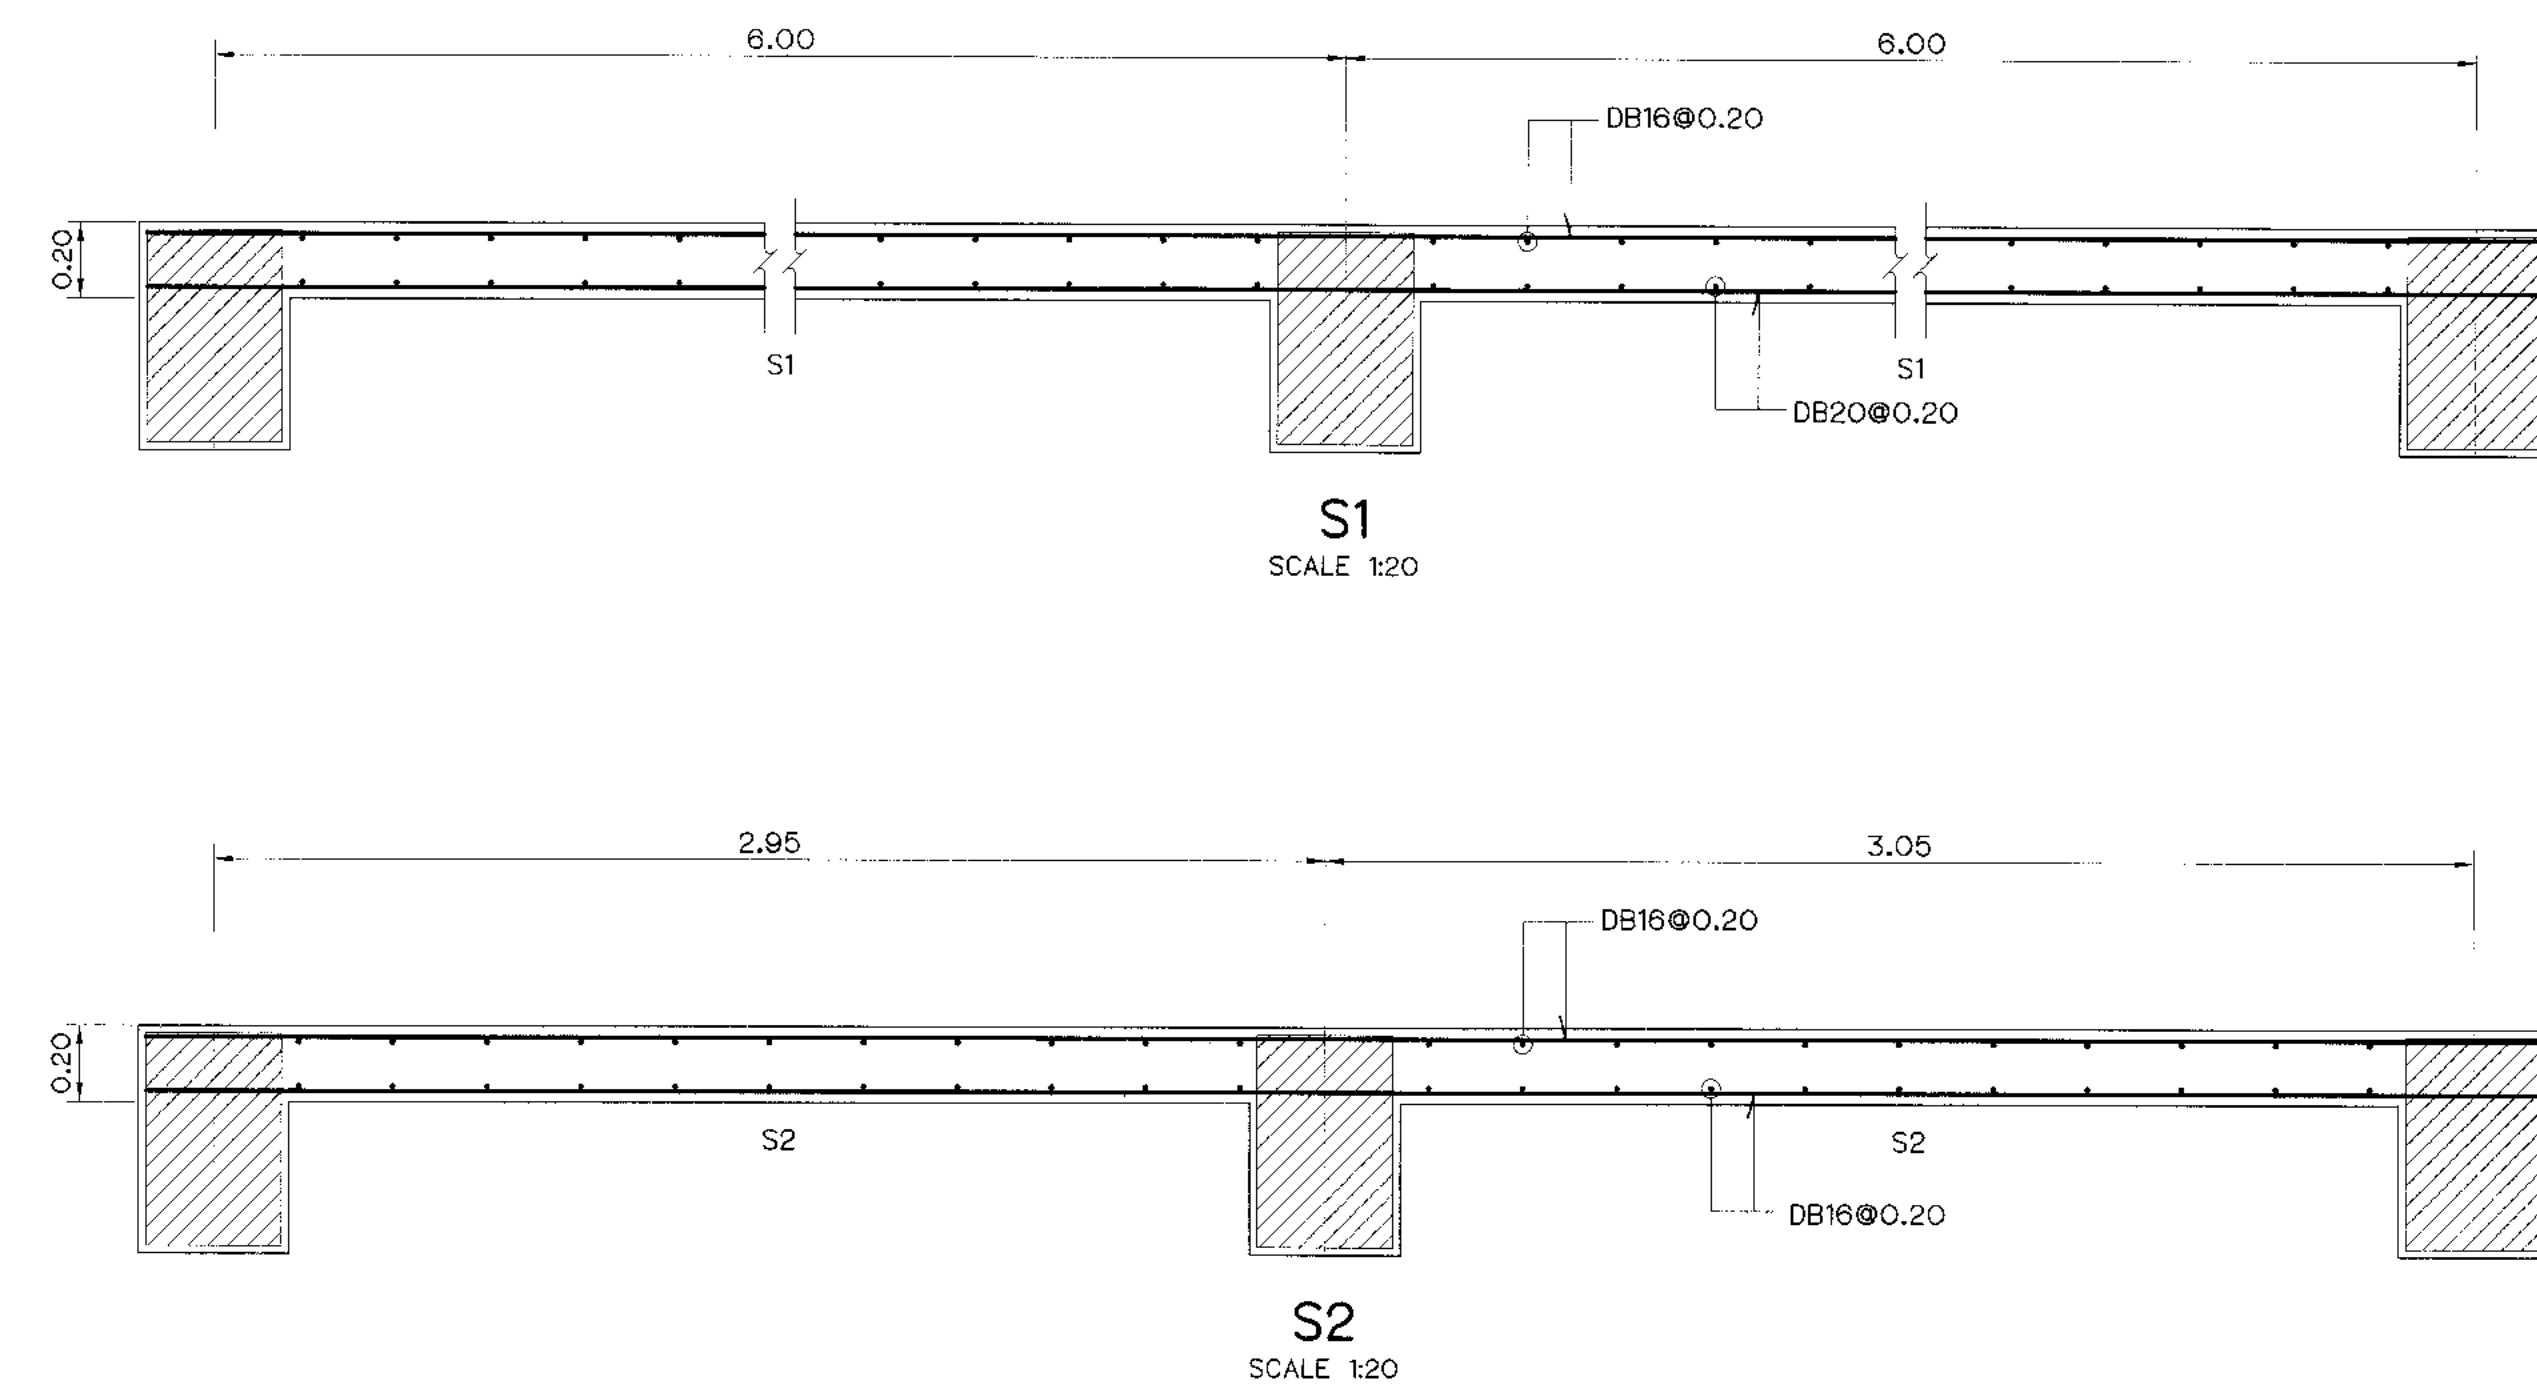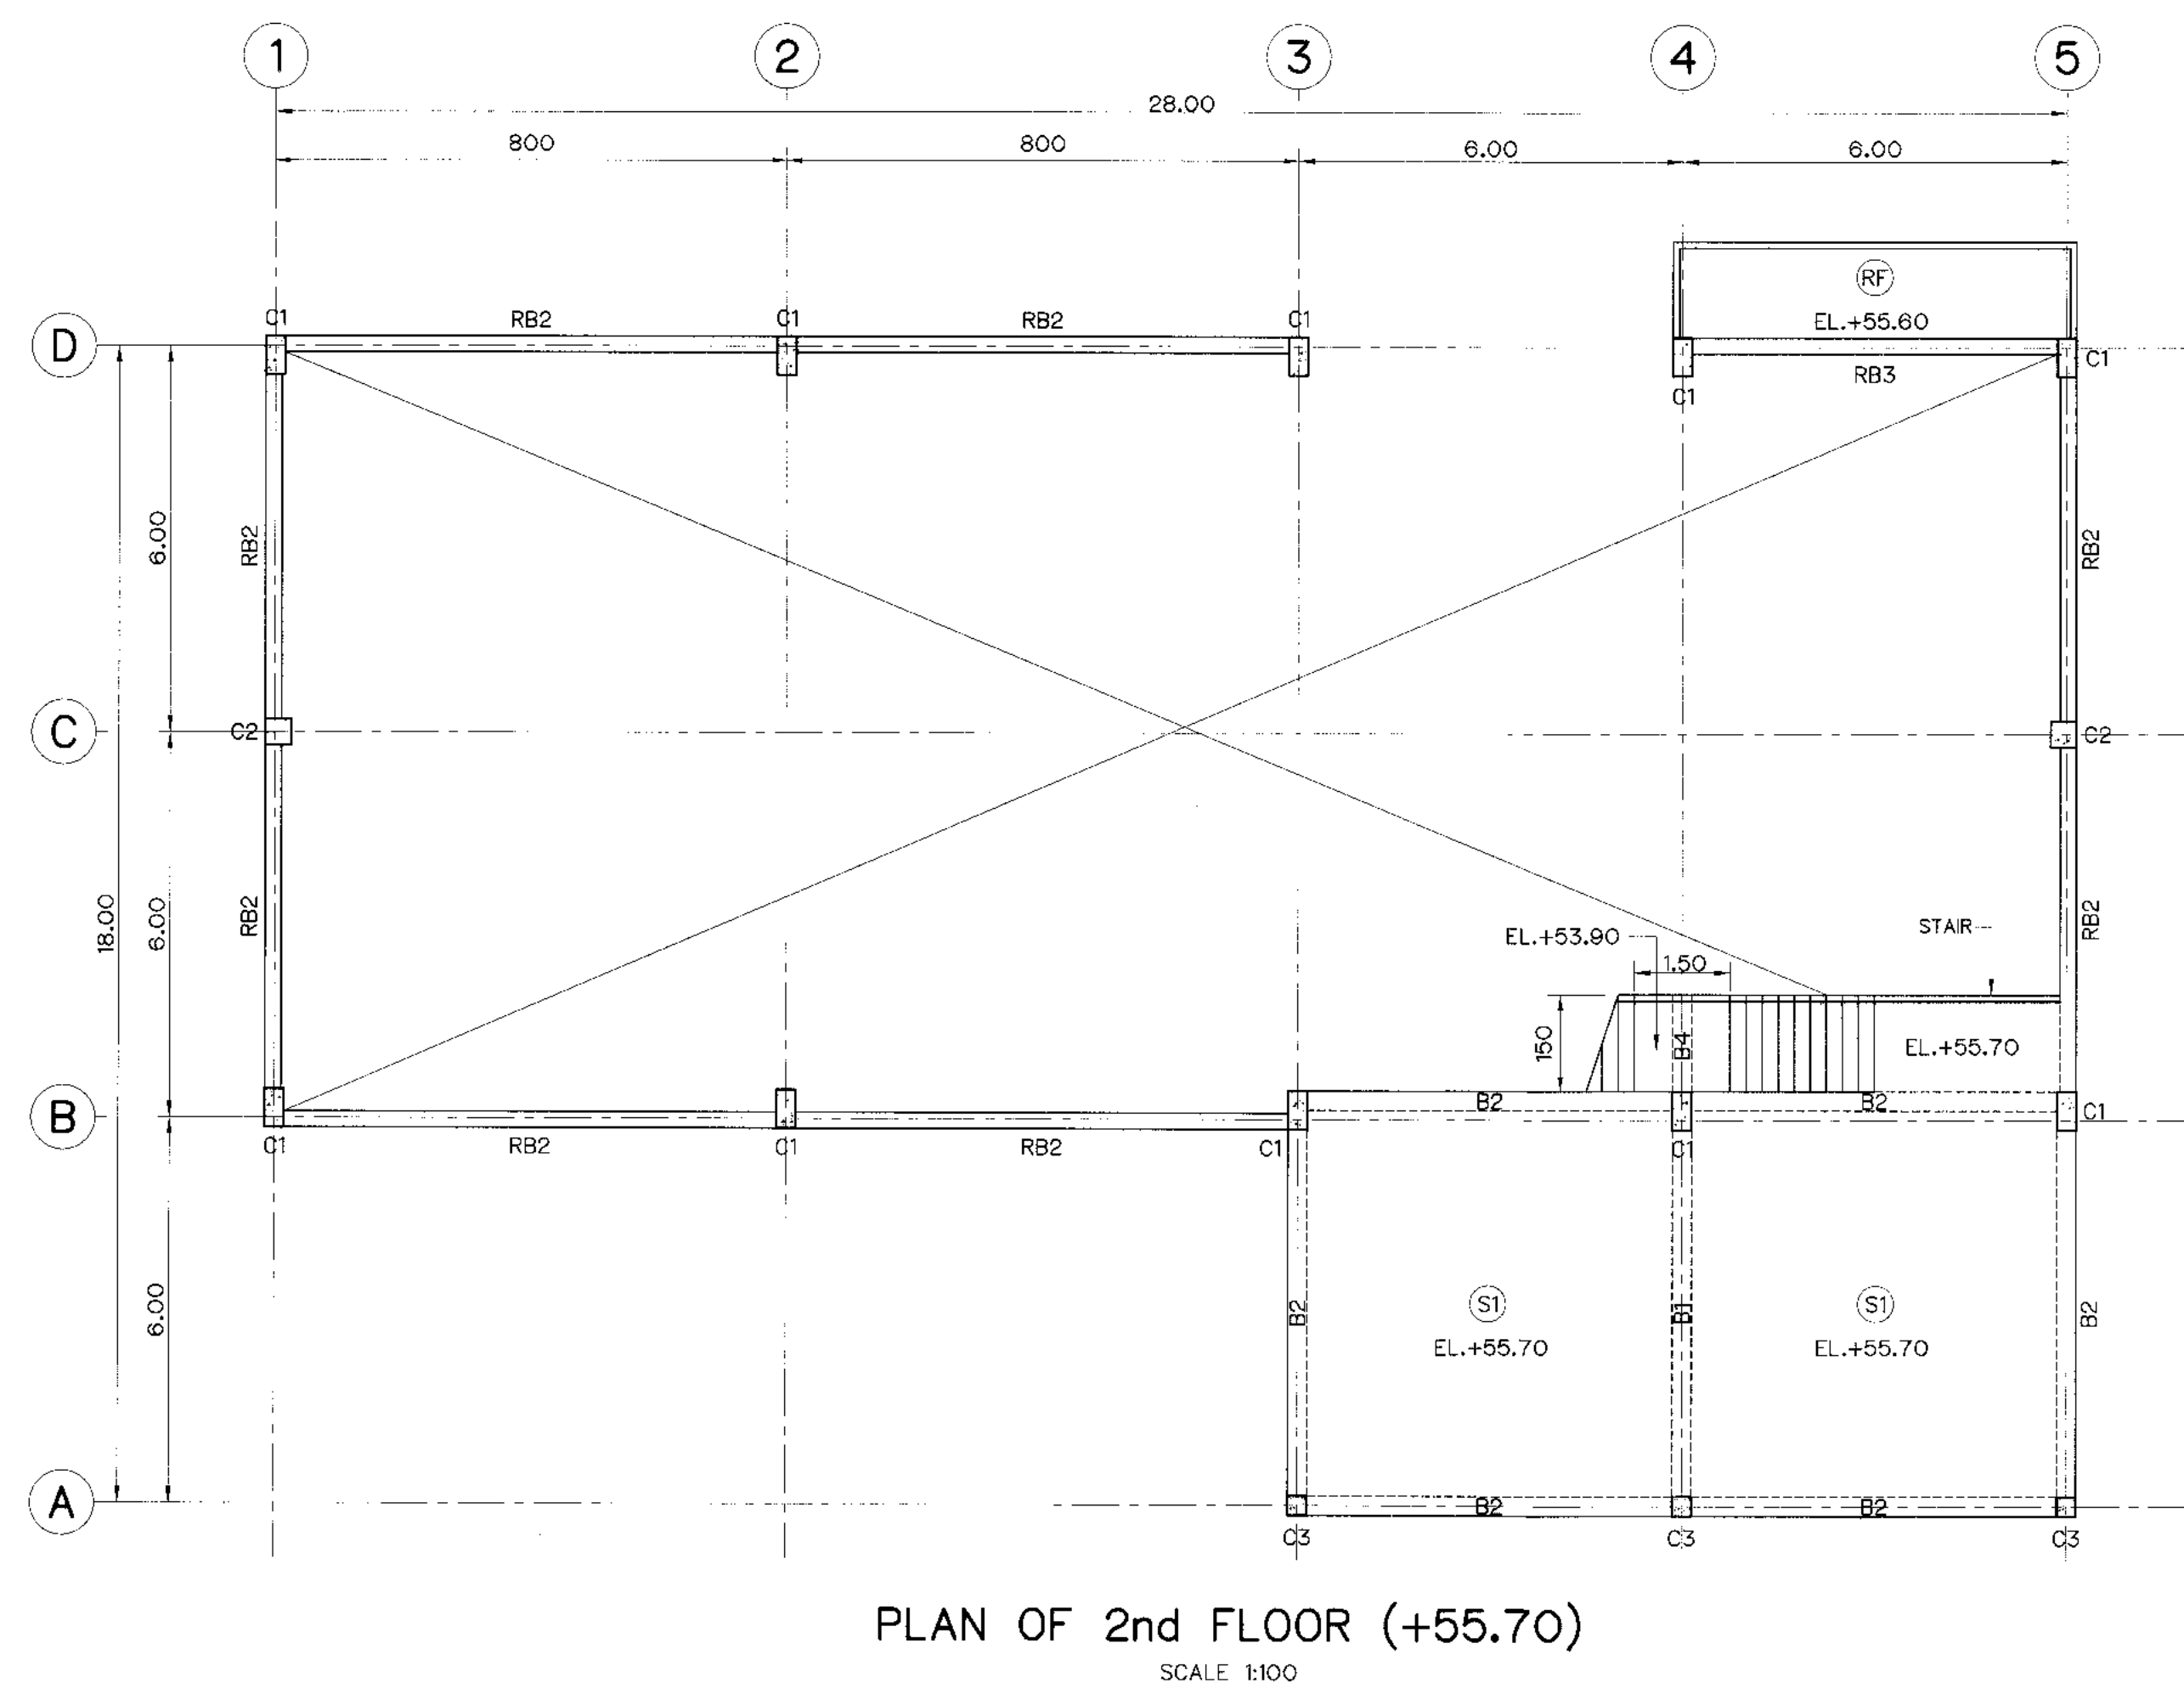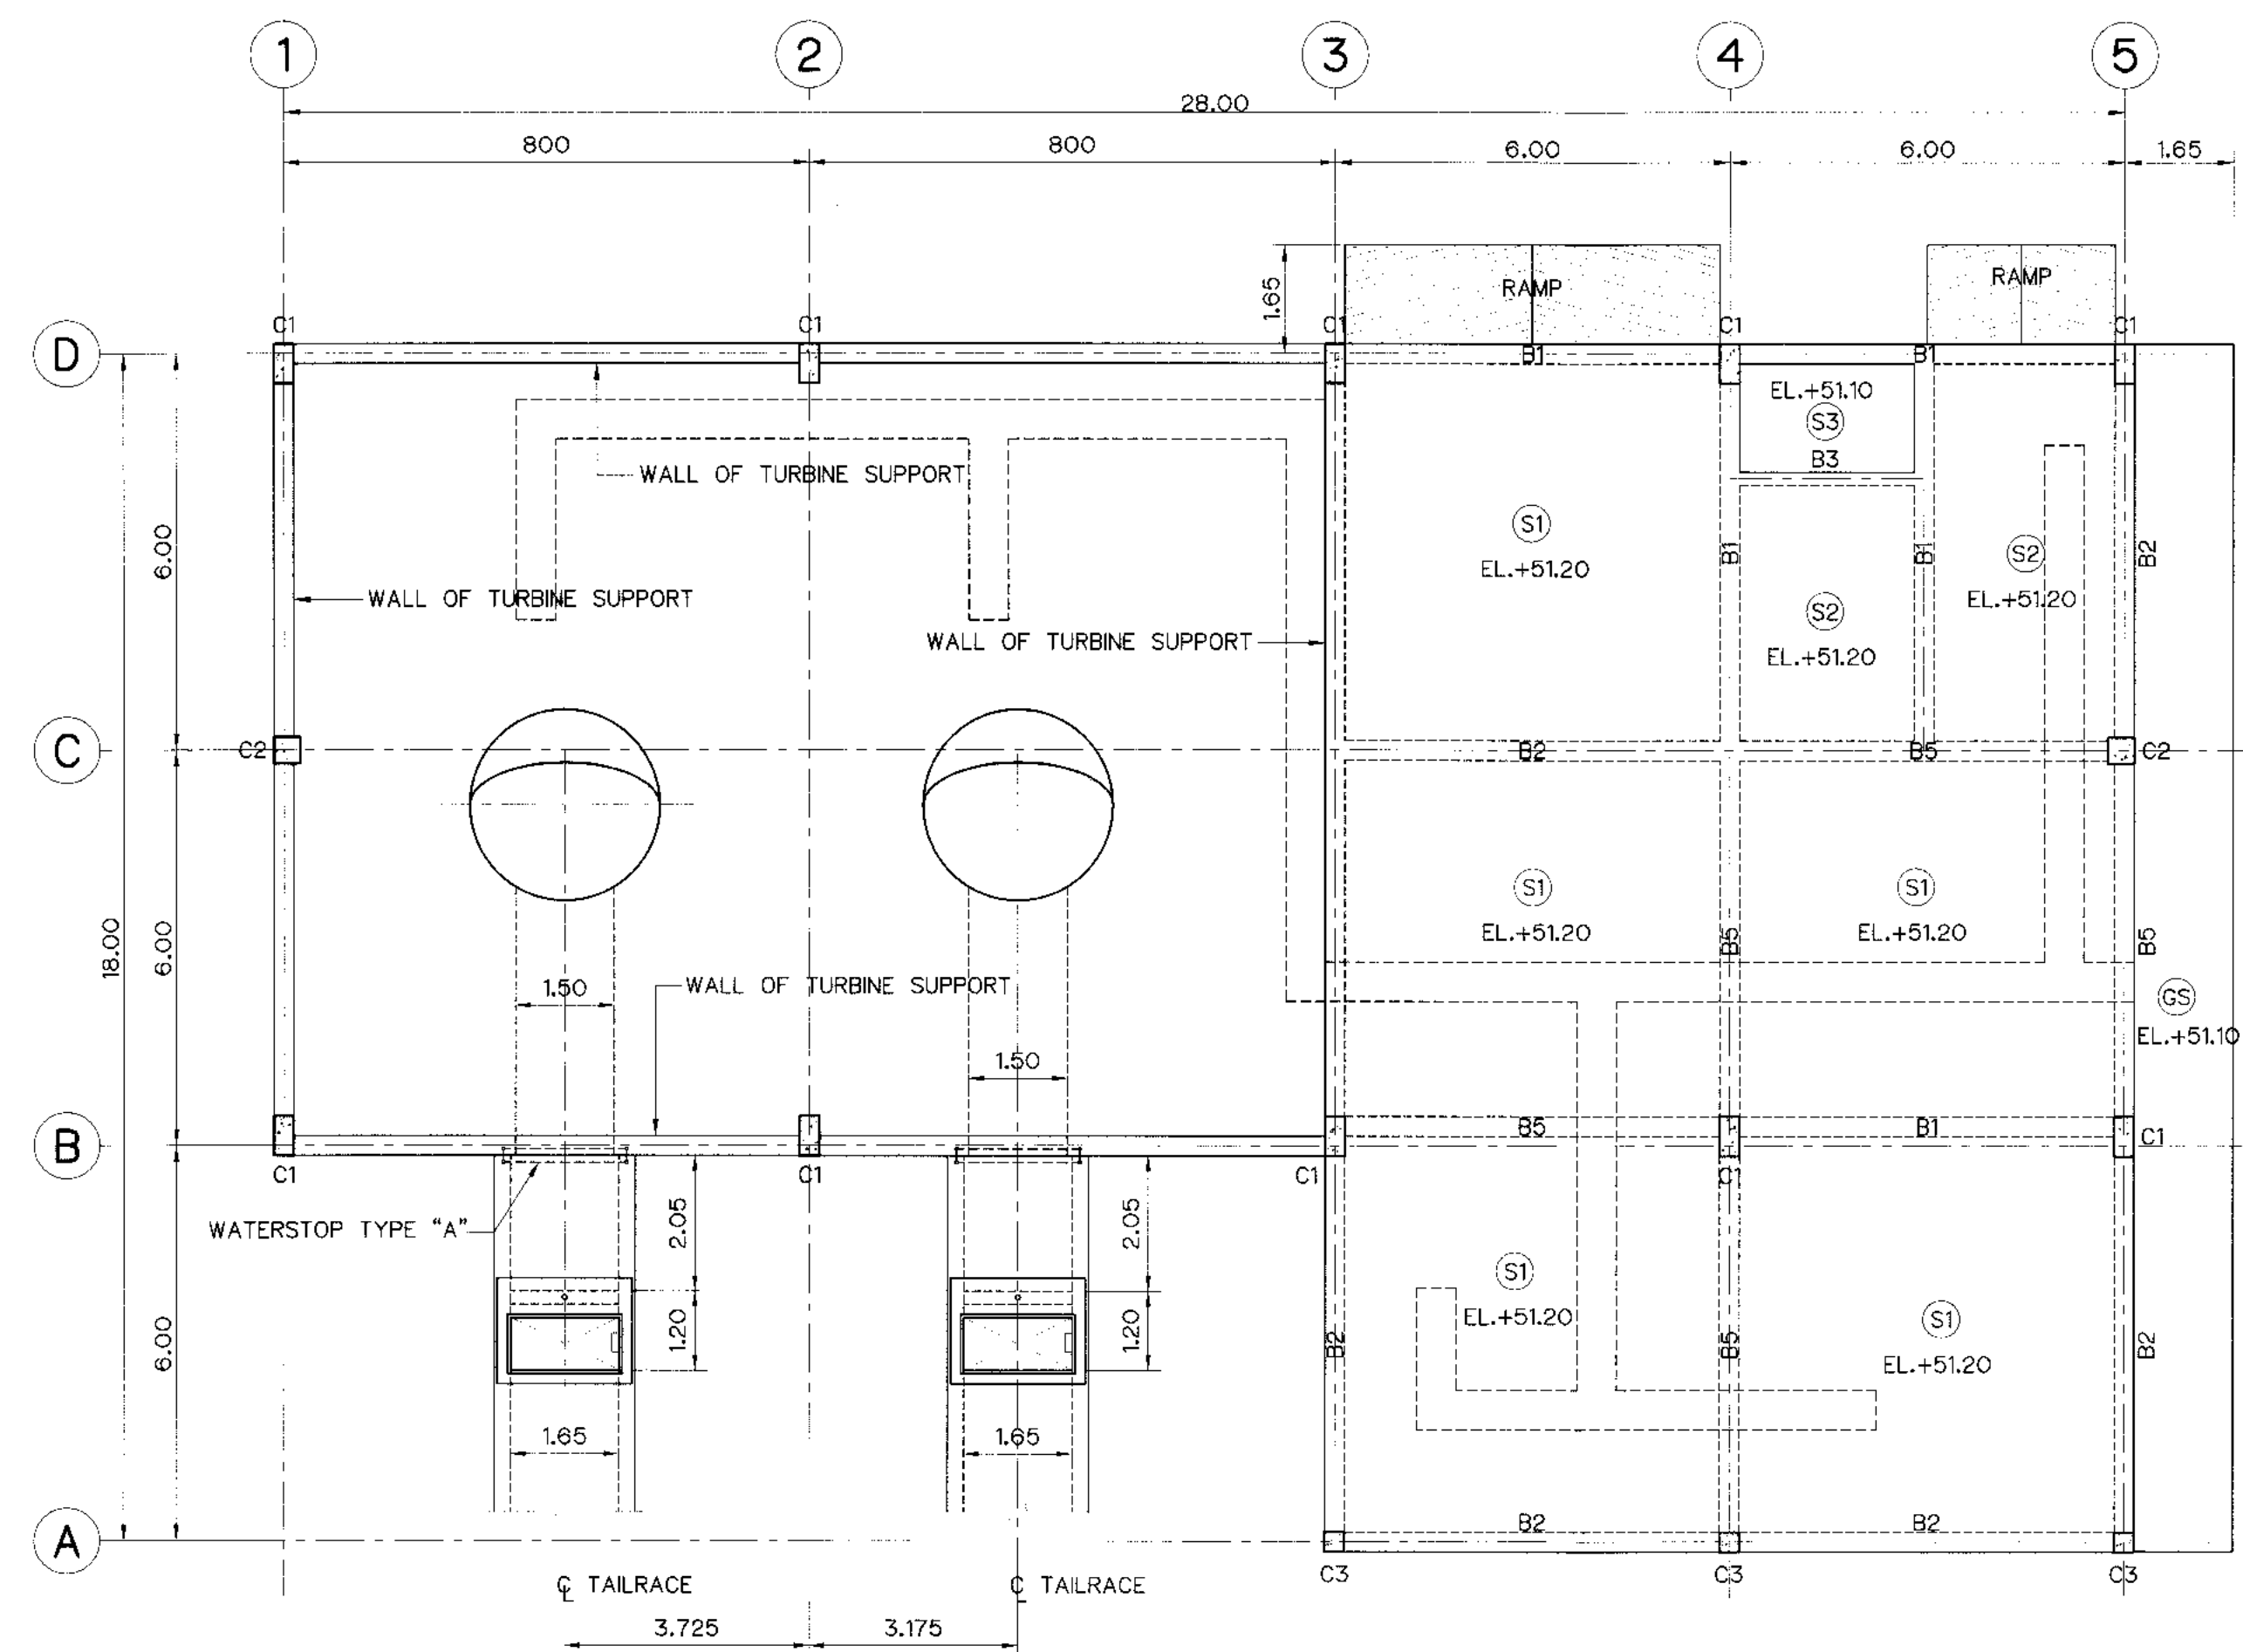


- NOTES :**
1. ALL DIMENSIONS AND ELEVATIONS (M.S.L.) ARE IN METERS, UNLESS OTHERWISE SHOWN.
 2. SYMBOLS, ABBREVIATIONS AND GENERAL NOTES SEE DWG. NO. KLP-GN-03
 3. CONCRETE DESIGN BASED ON THE COMPRESSIVE STRENGTH OF 210 KSC, STANDARD CYLINDER Ø0.15x0.30 m. TEST AT AGE 28 DAYS. UNLESS OTHERWISE INDICATED IN SPECIFIC DRAWINGS.

- REFERENCE DRAWINGS :
1. POWERHOUSE, PLAN 1st FLOOR
- KLP-PH-02


 KINGDOM OF THAILAND Department of Alternative Energy Development and Efficiency MINISTRY OF ENERGY	
KLONG LAM PLOK HYDROPOWER PROJECT	
CIVIL WORKS AND TRANSMISSION LINE POWERHOUSE PLAN OF SLAB AND DETAILS (1/2)	
 P&C MANAGEMENT CO., LTD.	 Department of Alternative Energy Development and Efficiency MINISTRY OF ENERGY
DESIGNED <i>[Signature]</i> 218.29074 218.29074 218.29074	REVIEWED <i>[Signature]</i>
DRAWN <i>[Signature]</i>	SUBMITTED <i>[Signature]</i>
CHECKED <i>[Signature]</i> 218.29074 218.29074	APPROVED <i>[Signature]</i>
<i>[Signature]</i> PROJECT MANAGER	DRAWING NO. KLP-PH-10
DATE	SHEET NO. 82 OF 110

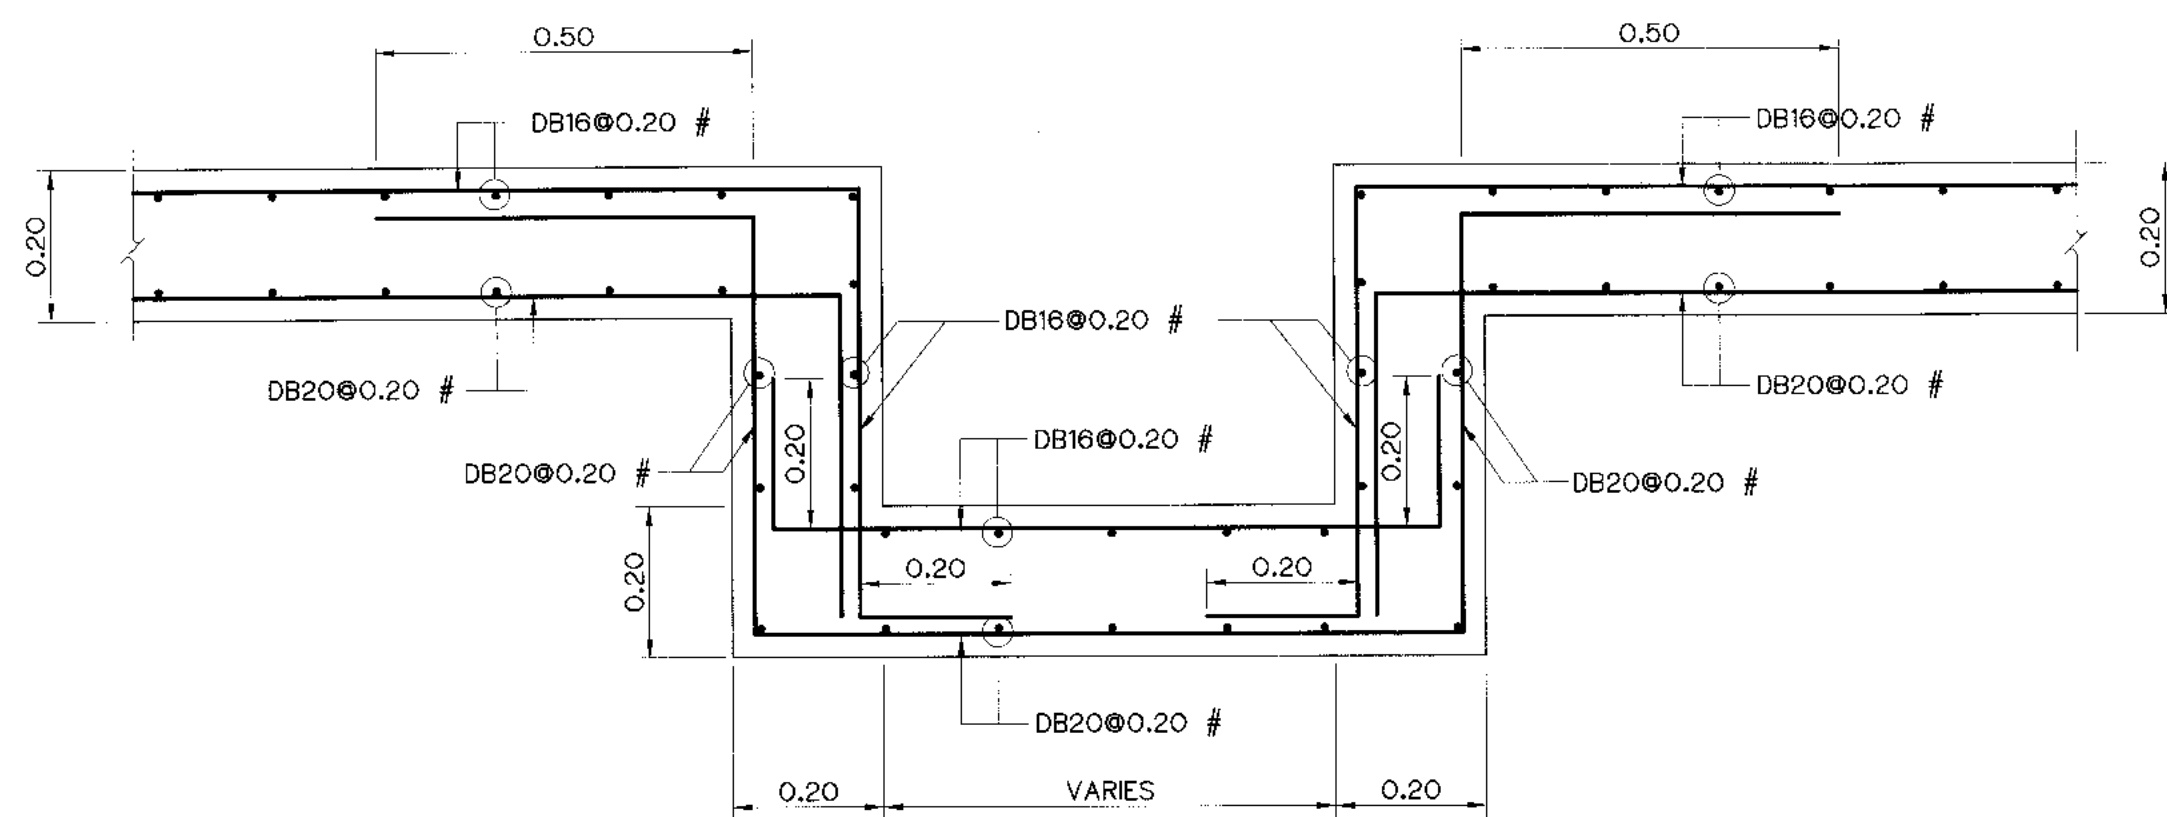


REINFORCEMENT DETAILS OF CABLE TRENCH AT SLAB S1
SCALE 1:10

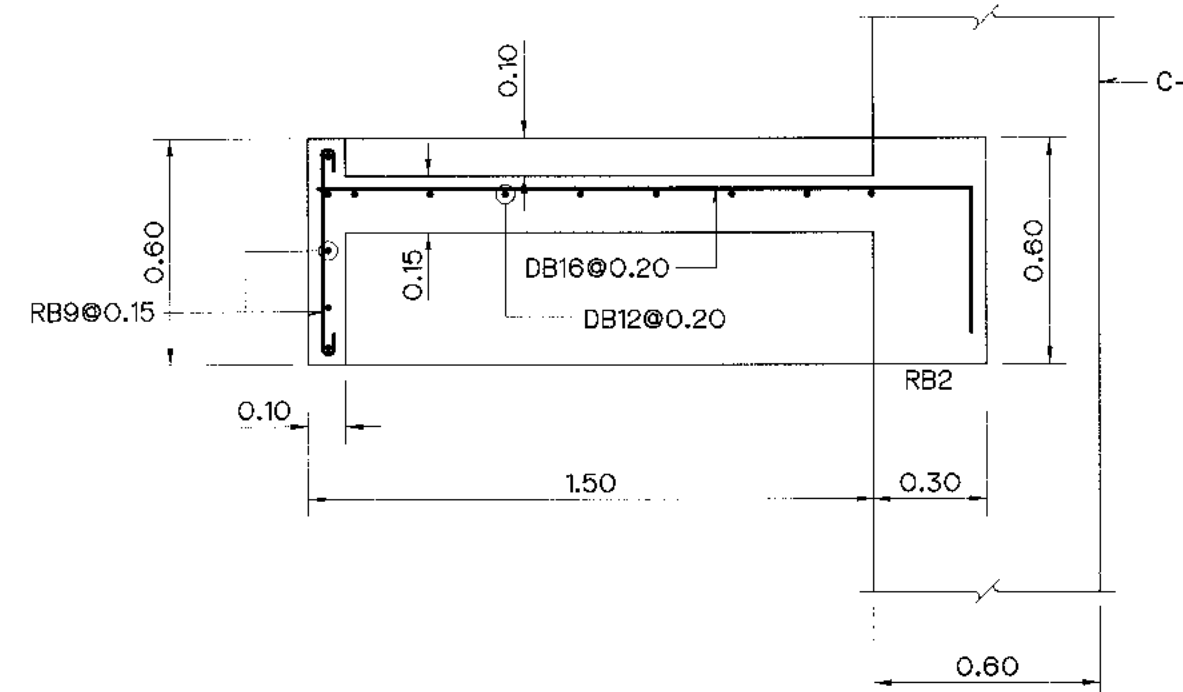


RF
SCALE 1:20

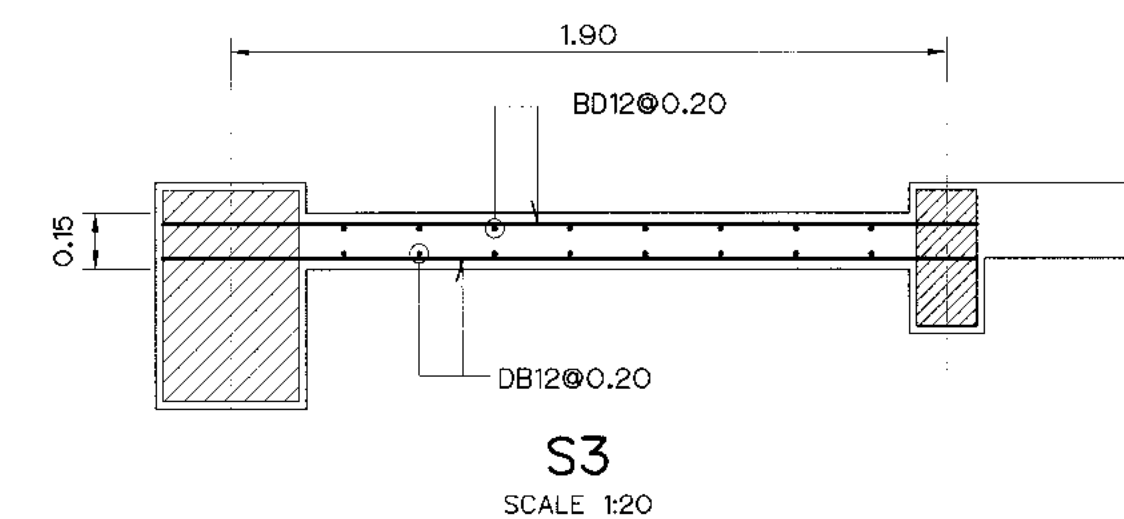


S3
SCALE 1:20

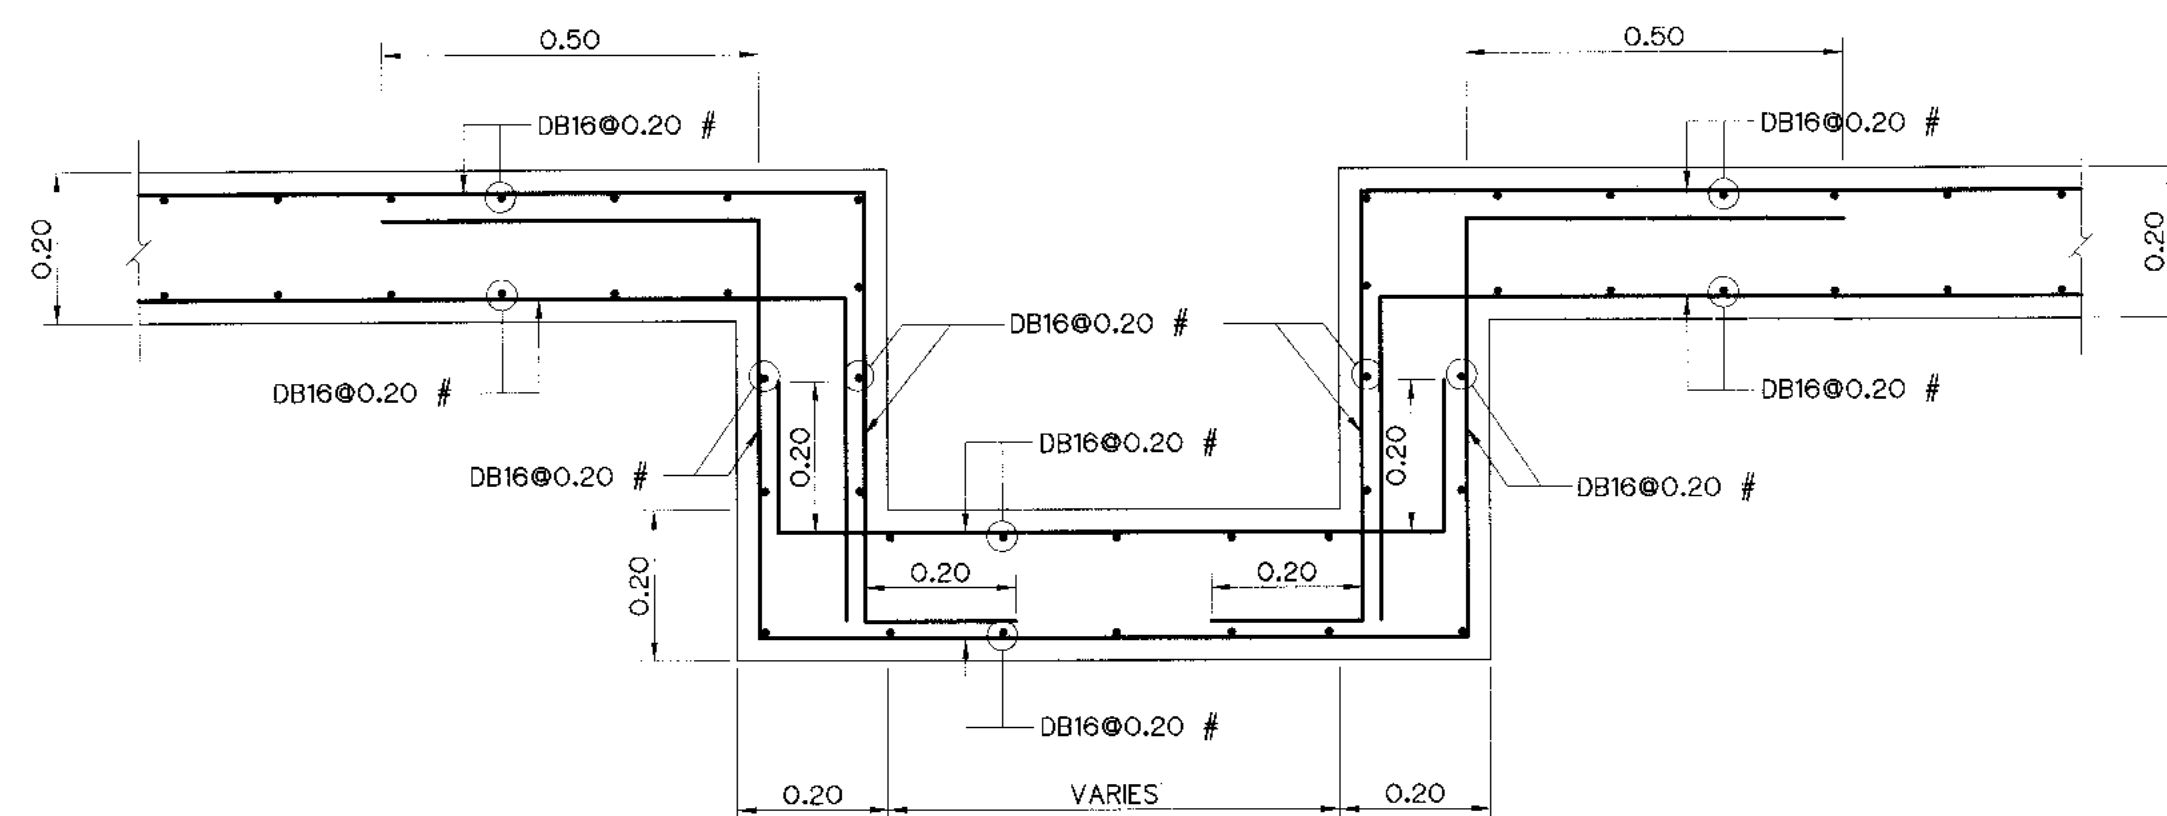

REINFORCEMENT DETAILS OF CABLE TRENCH AT SLAB S2
SCALE 1:10

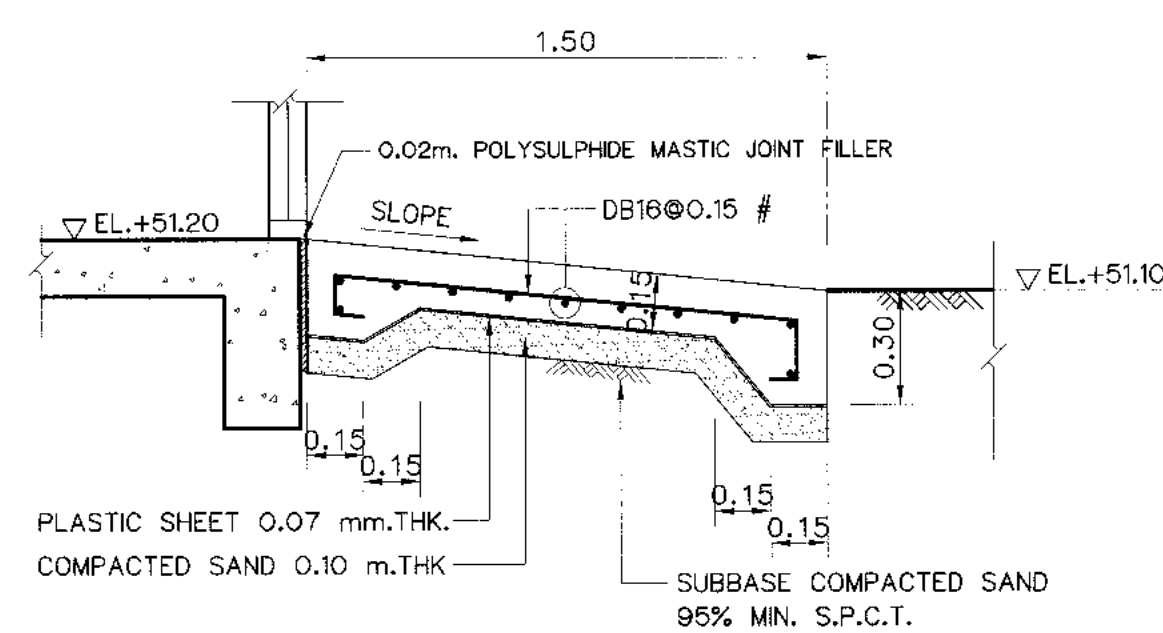


RAMP
SCALE 1:20

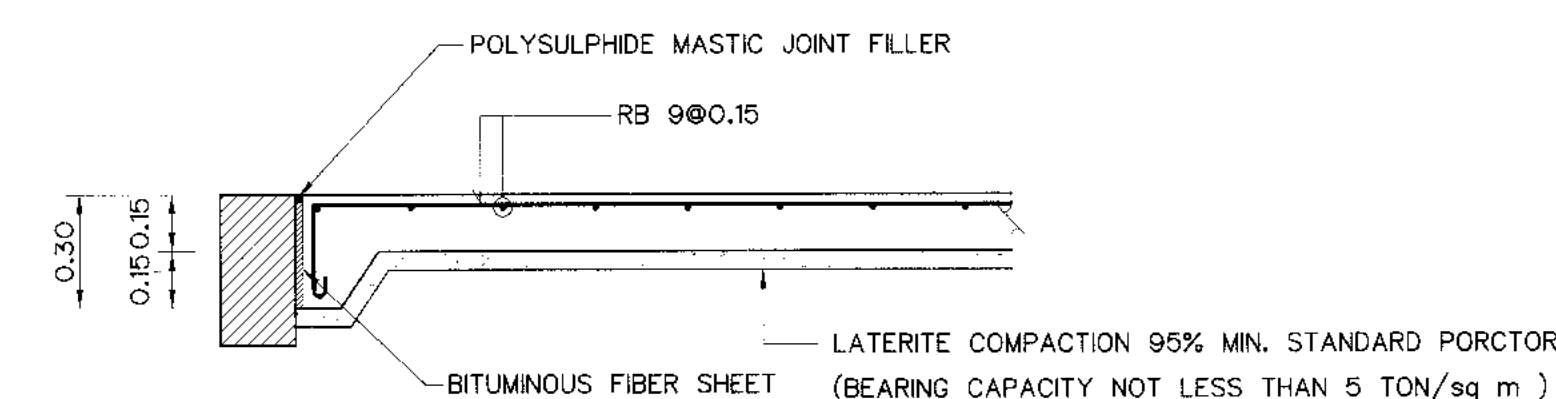

GS
SCALE 1:20


- NOTES :
1. ALL DIMENSIONS AND ELEVATIONS (M.S.L.) ARE IN METERS, UNLESS OTHERWISE SHOWN.
 2. SYMBOLS, ABBREVIATIONS AND GENERAL NOTES SEE DWG. NO. KLP-GN-03
 3. CONCRETE DESIGN BASED ON THE COMPRESSIVE STRENGTH OF 210 KSC. STANDARD CYLINDER Ø0.15x0.30 m. TEST AT AGE 28 DAYS. UNLESS OTHERWISE INDICATED IN SPECIFIC DRAWINGS.

- REFERENCE DRAWINGS :
1. POWERHOUSE, PLAN 1st FLOOR KLP-PH-02

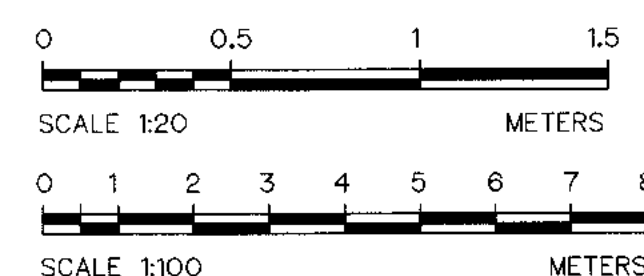


3				
2				
1				
NO.	DATE	REVISIONS	CHECKED	APPROVED


KINGDOM OF THAILAND Department of Alternative Energy Development and Efficiency MINISTRY OF ENERGY			
KLONG LAM PLOK HYDROPOWER PROJECT			
CIVIL WORKS AND TRANSMISSION LINE			
POWERHOUSE			
PLAN OF SLAB AND DETAILS (2/2)			
P&C MANAGEMENT CO.,LTD.		Department of Alternative Energy Development and Efficiency MINISTRY OF ENERGY	
DESIGNED	08/29/74	08/29/74	SUBMITTED
DRAWN			RECOMMENDED
CHECKED	08/22/26	08/22/26	APPROVED
PROJECT MANAGER		DRAWING NO. KLP-PH-11	
DATE		SHEET NO. 83 OF 110	

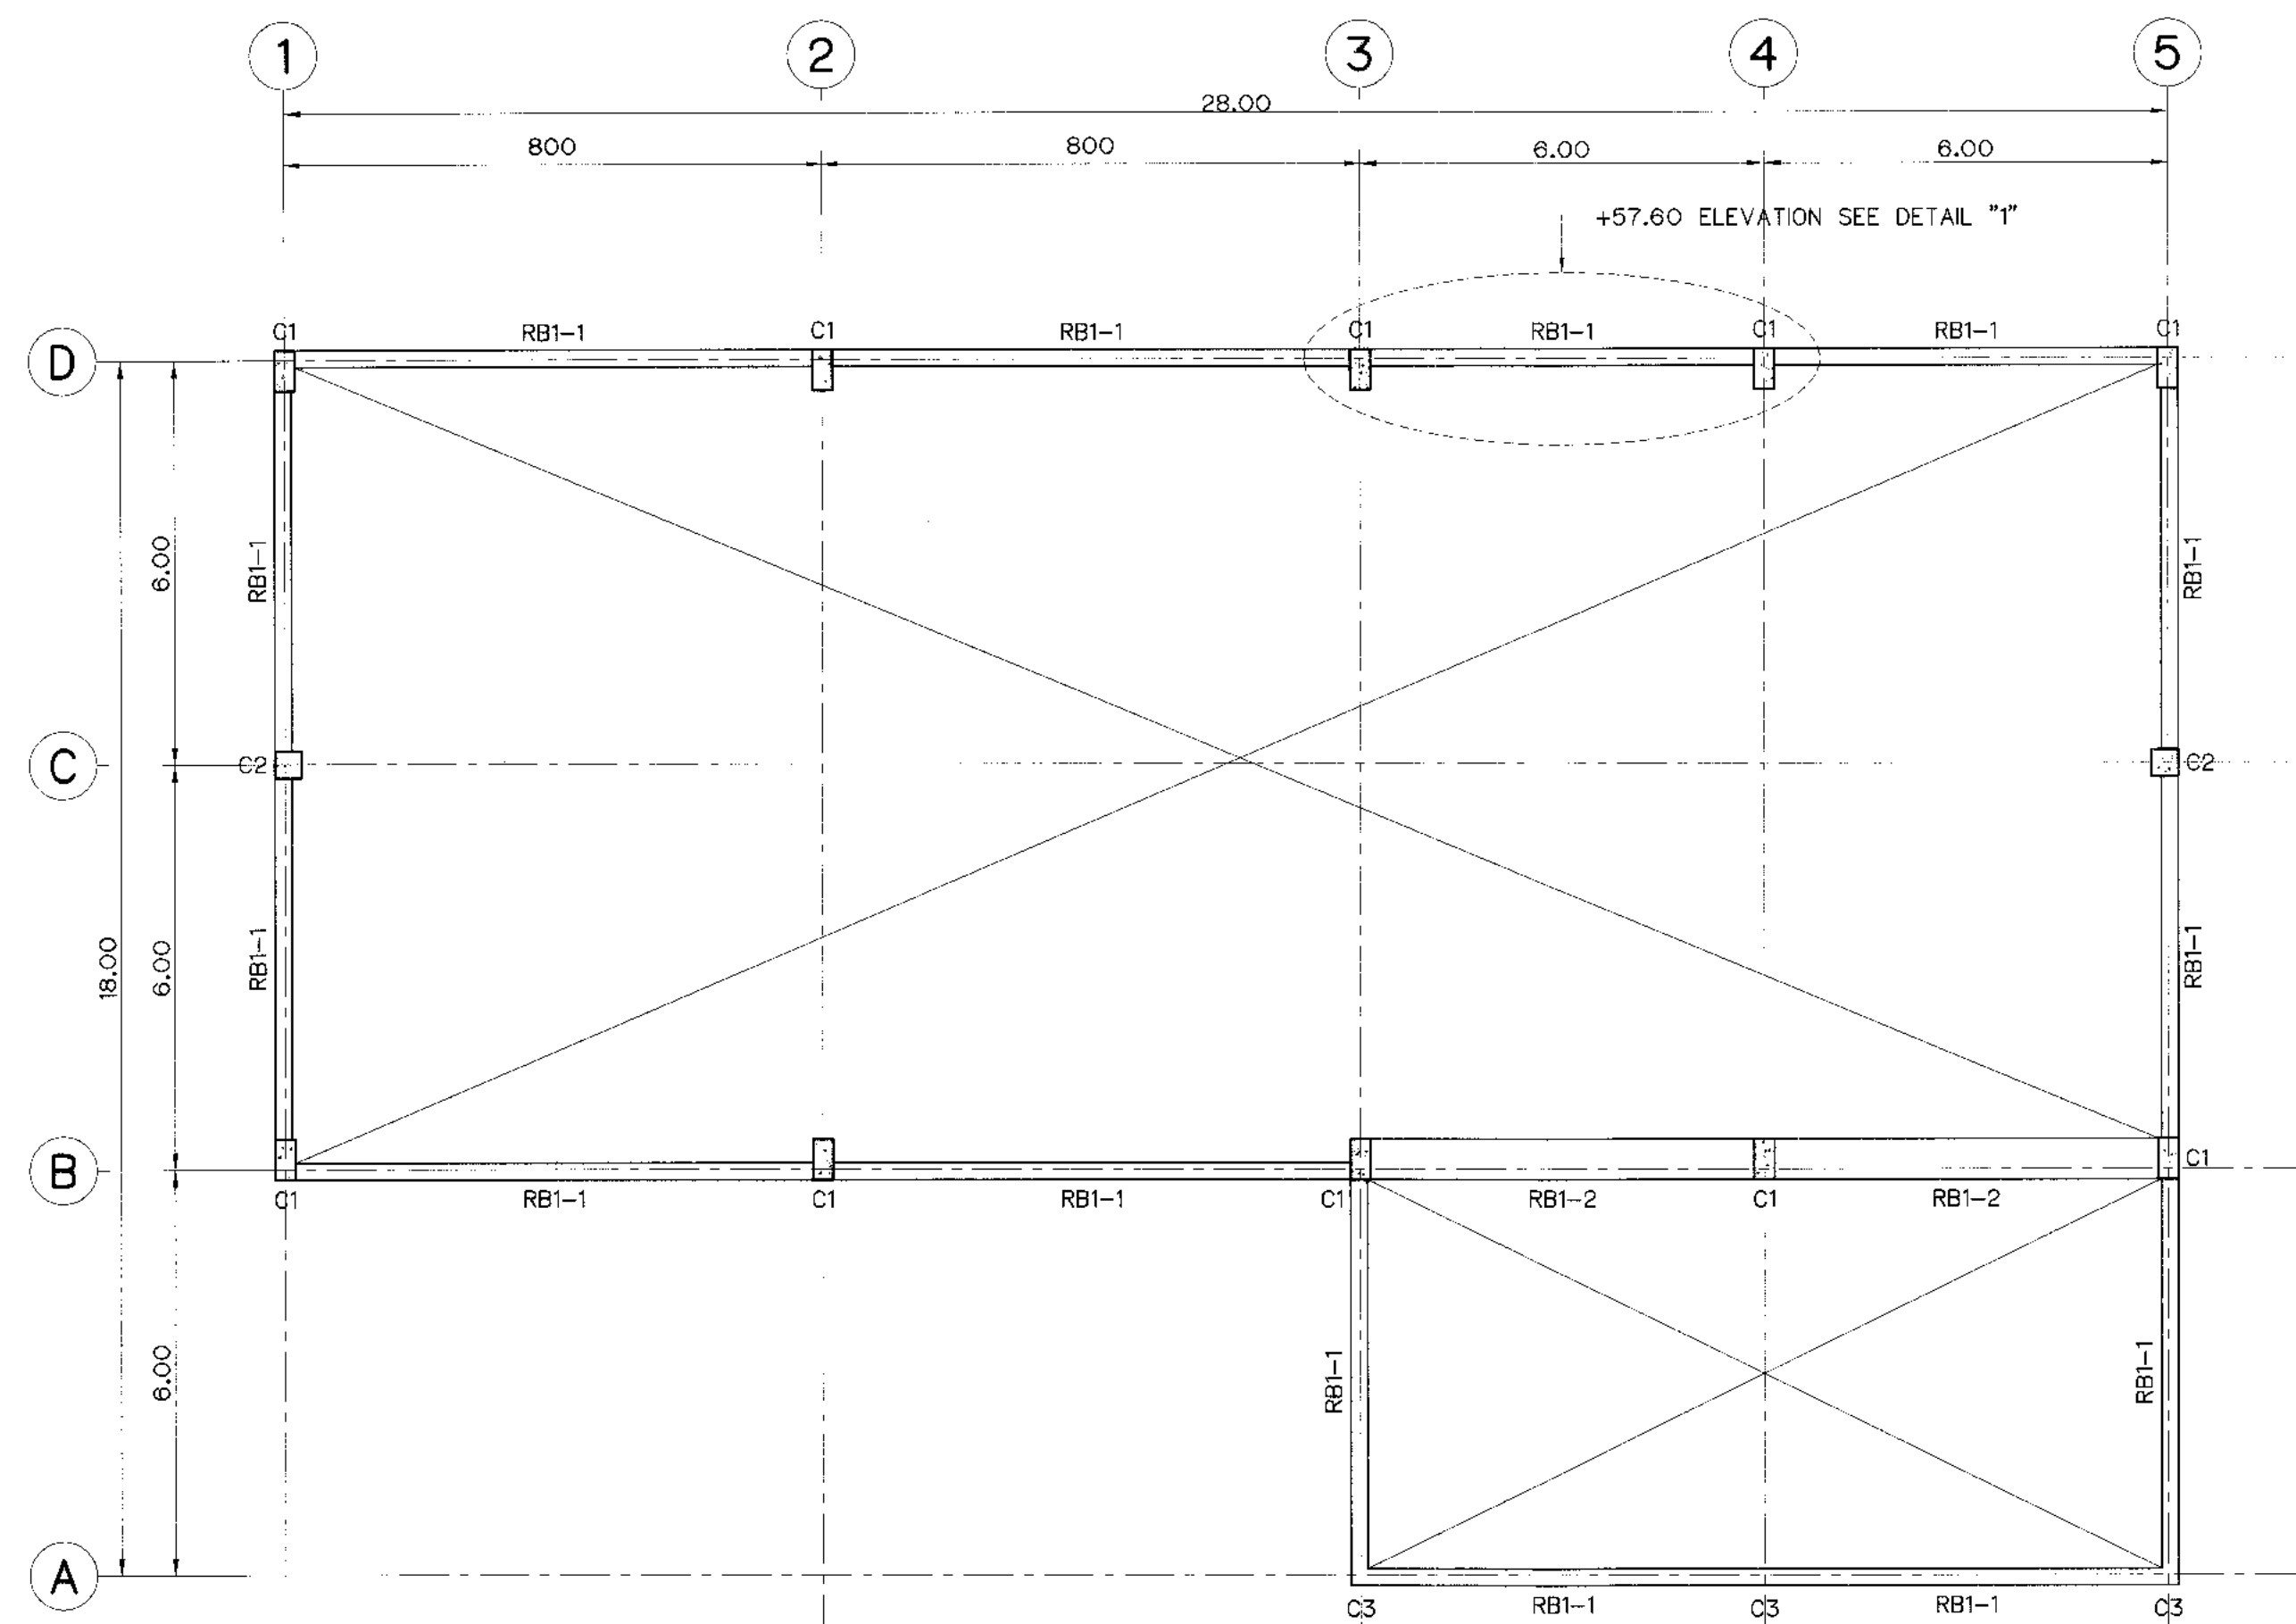


+59.70 ELEVATION PLAN
SCALE 1:100

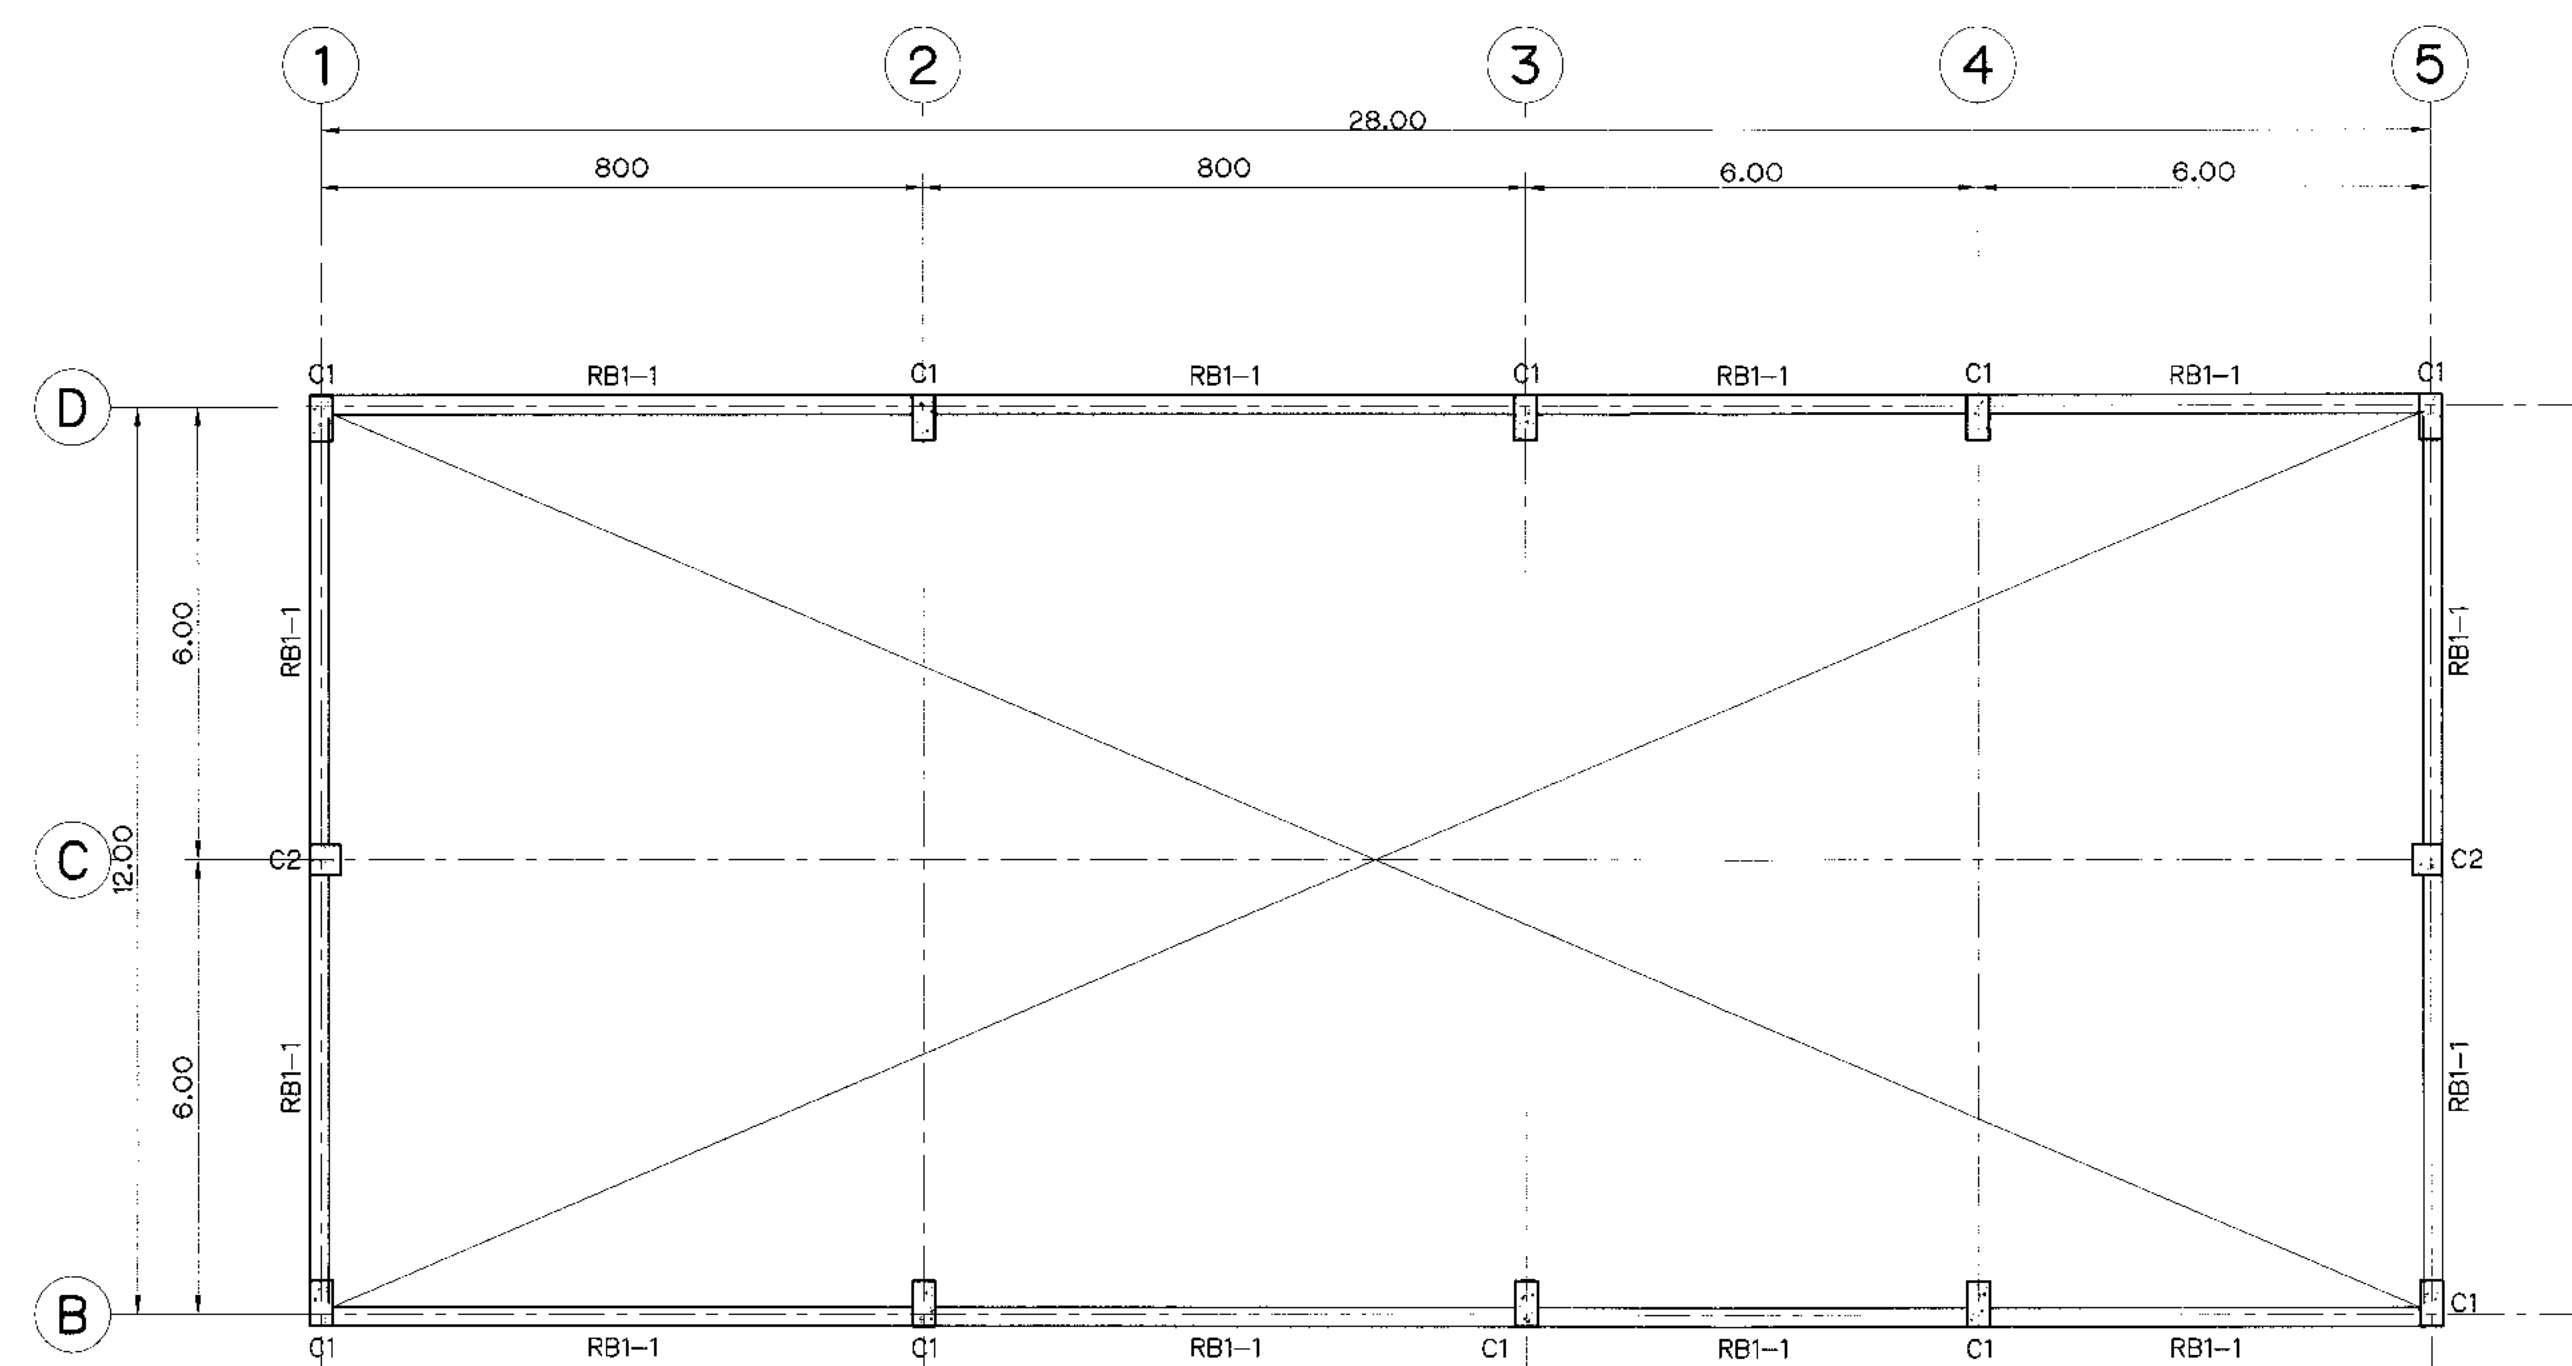


+62.20 ELEVATION PLAN
SCALE 1:100

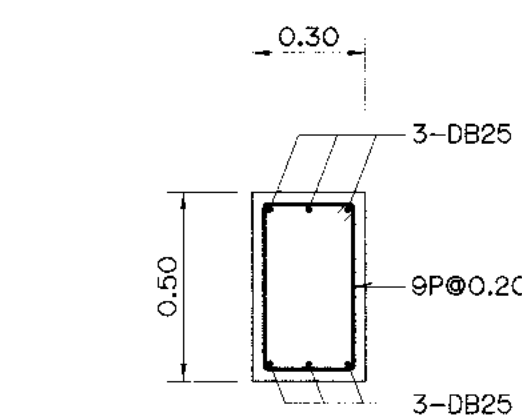


RB1-1
SCALE 1:20

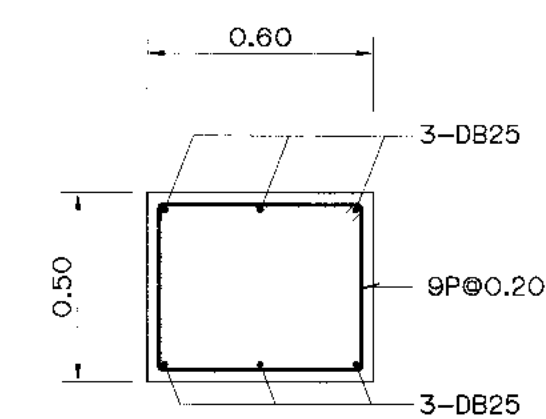


RB1-2
SCALE 1:20

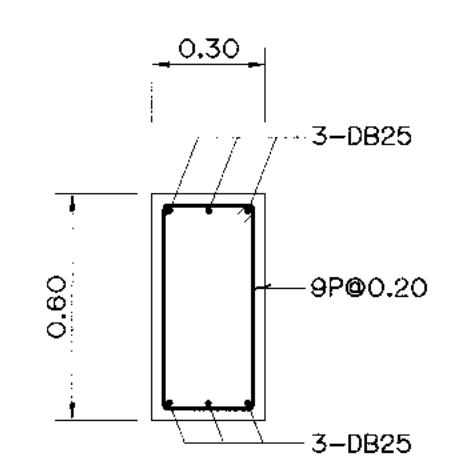


RB2
SCALE 1:20

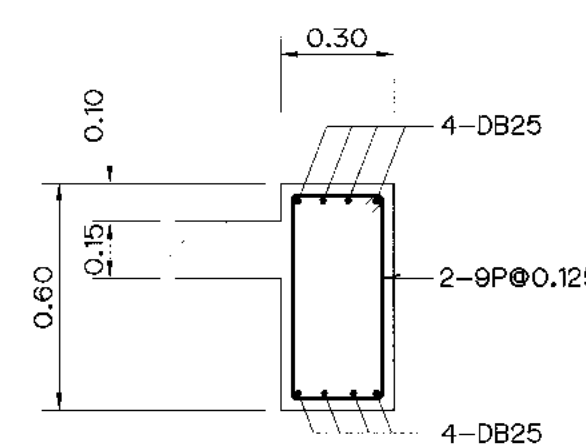


RB3
SCALE 1:20

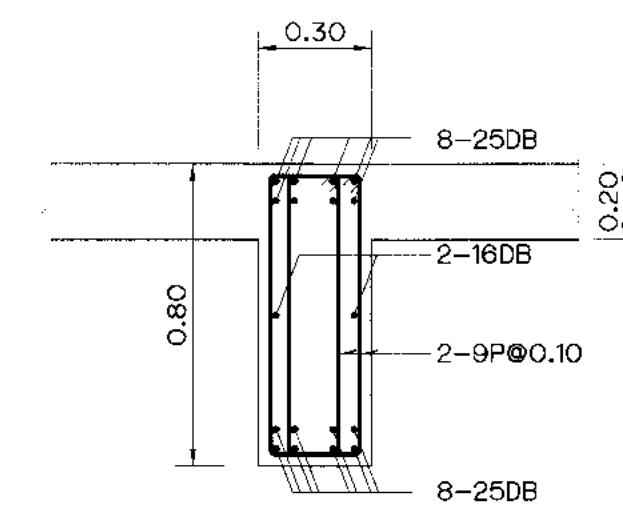


B1
SCALE 1:20

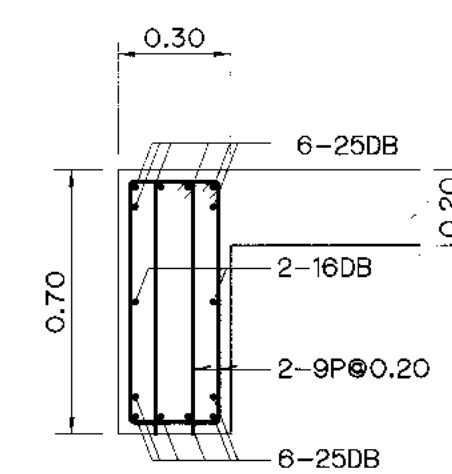


B2
SCALE 1:20

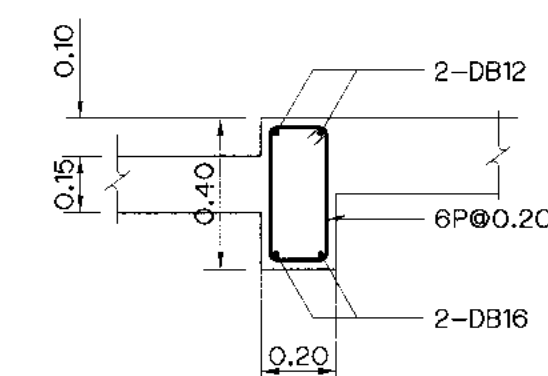

B3
SCALE 1:20

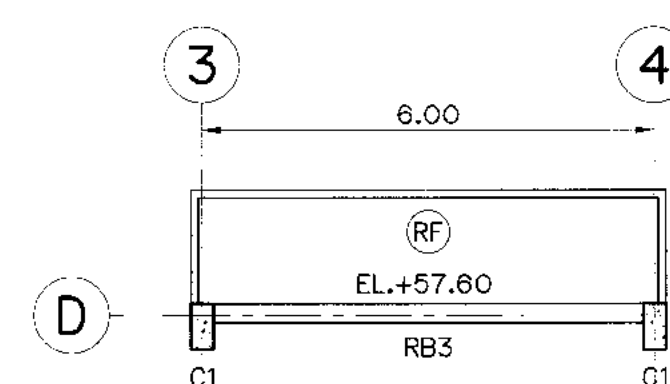

DETAIL "1"
SCALE 1:100

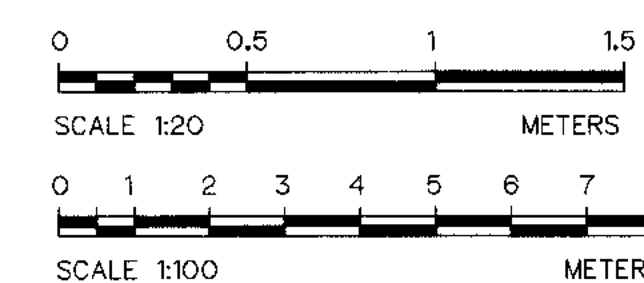














NOTES :

1. ALL DIMENSIONS AND ELEVATIONS (M.S.L.) ARE IN METERS, UNLESS OTHERWISE SHOWN.
2. SYMBOLS, ABBREVIATIONS AND GENERAL NOTES SEE DWG. NO. KLP-GN-03
3. CONCRETE DESIGN BASED ON THE COMPRESSIVE STRENGTH OF 210 KSC, STANDARD CYLINDER $\phi 0.15 \times 0.30$ m. TEST AT AGE 28 DAYS. UNLESS OTHERWISE INDICATED IN SPECIFIC DRAWINGS.

REFERENCE DRAWINGS :


1. POWERHOUSE, PLAN 1st FLOOR KLP-PH-02
2. POWERHOUSE, PLAN 2nd AND ROOF PLAN KLP-PH-03

KINGDOM OF THAILAND Department of Alternative Energy Development and Efficiency MINISTRY OF ENERGY	
KLONG LAM PLOK HYDROPOWER PROJECT	
CIVIL WORKS AND TRANSMISSION LINE	
POWERHOUSE	
BEAMS DETAILS	
P&C MANAGEMENT CO.,LTD. DESIGNED: 28/07/2564 28/02/26 DRAWN: 28/02/26 CHECKED: 28/02/26 PROJECT MANAGER: 08/03/2559	MINISTRY OF ENERGY REVIEWED: 28/02/26 SUBMITTED: 28/02/26 RECOMMENDED: 28/02/26 APPROVED: 28/02/26 DATE: 08/03/2559
DRAWING NO. KLP-PH-12	SHEET NO. 84 OF 110

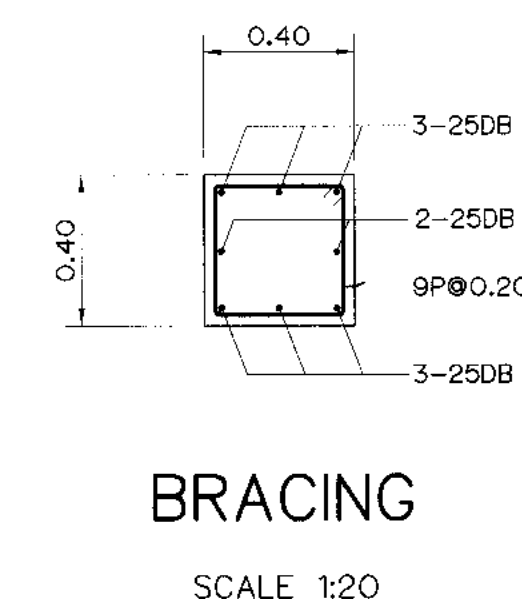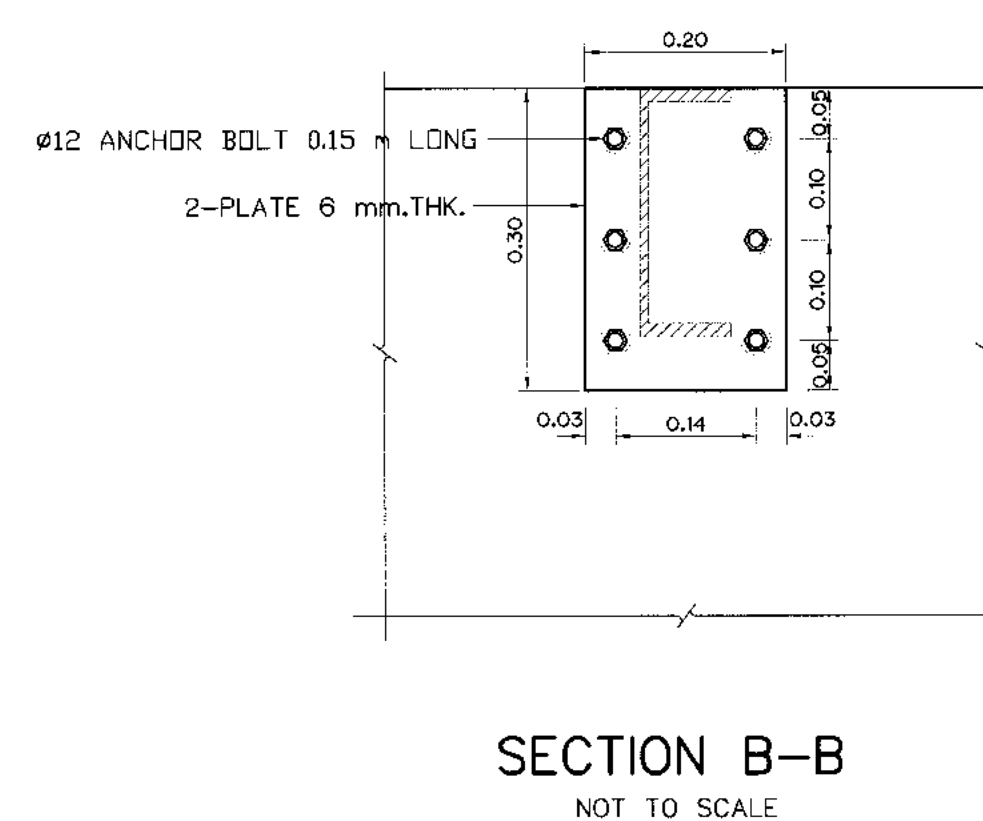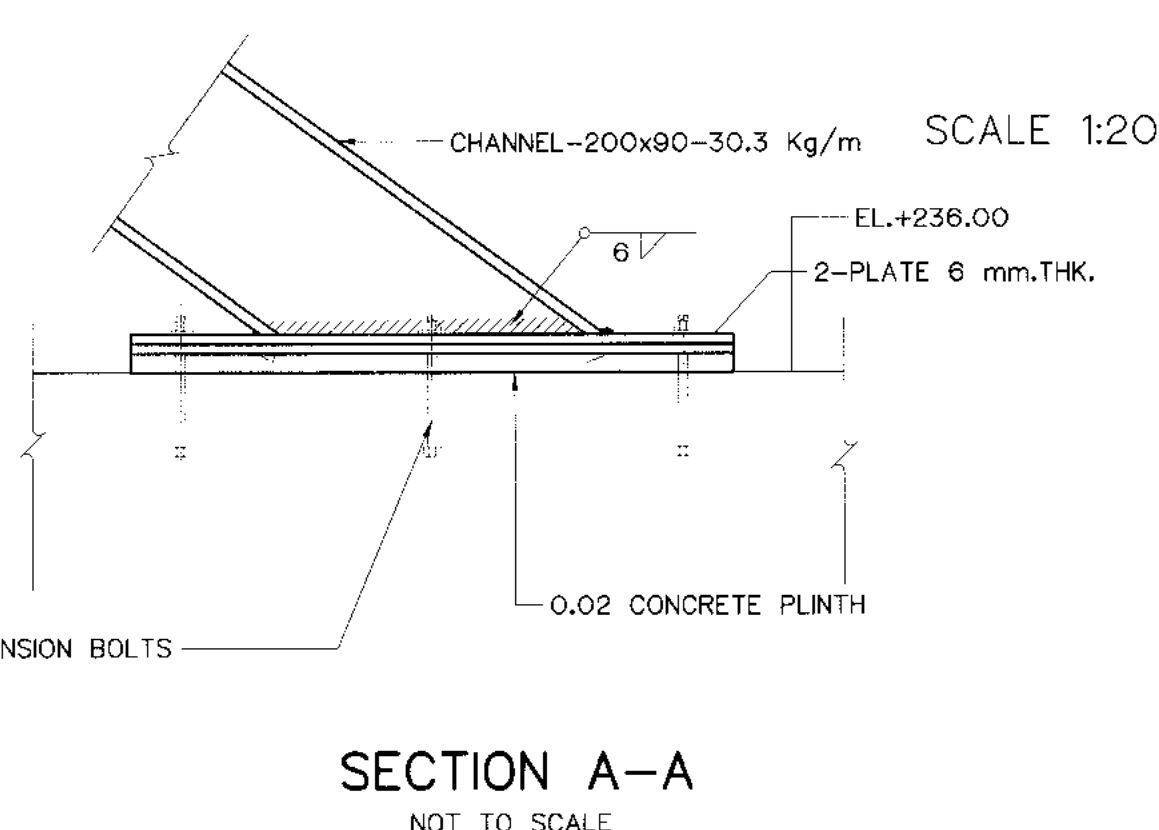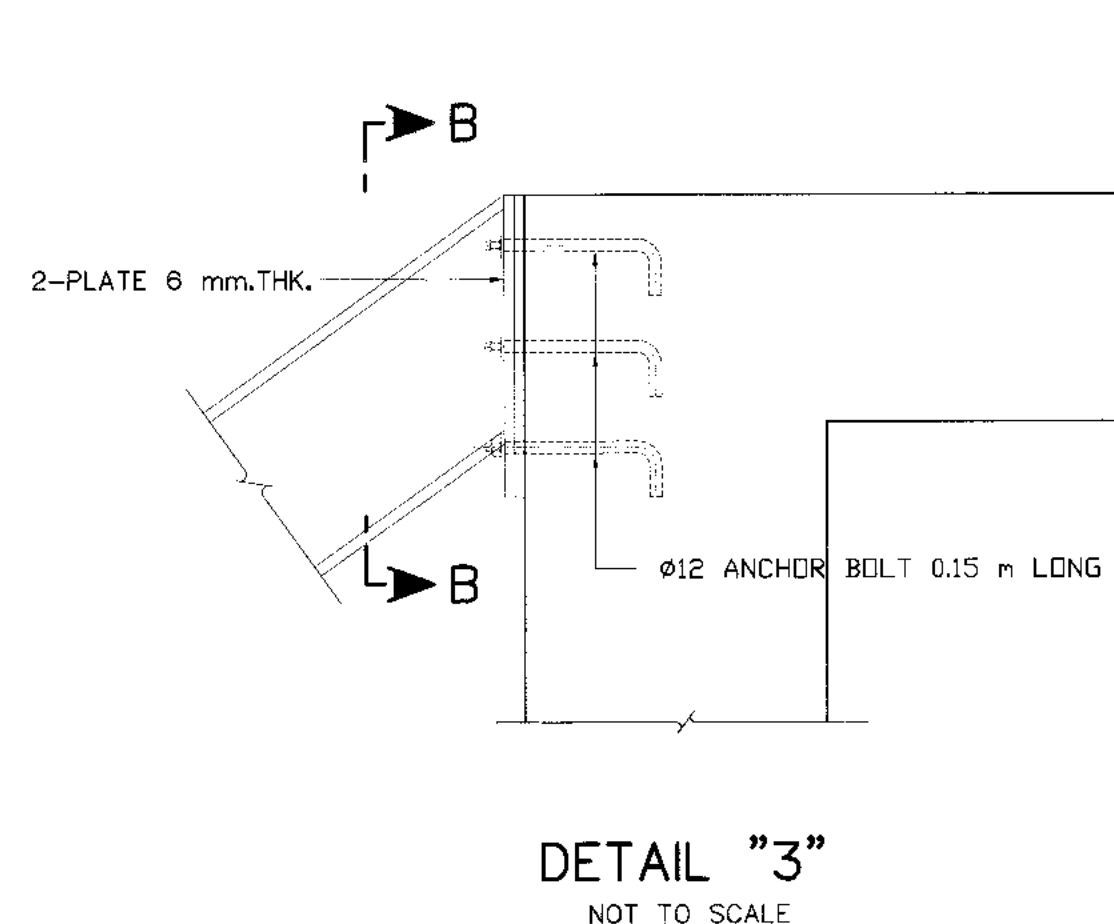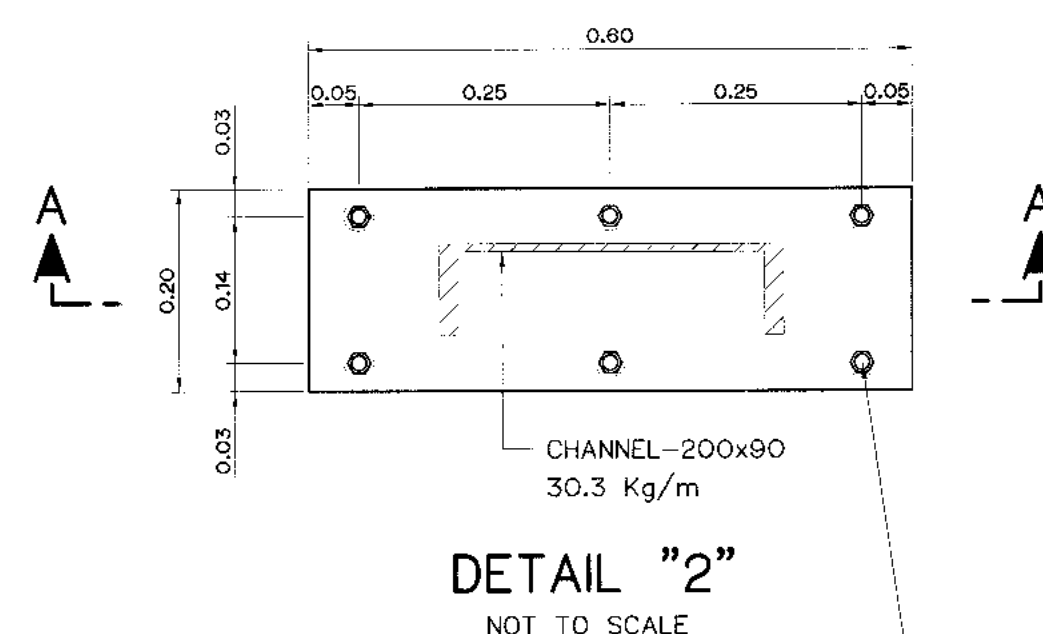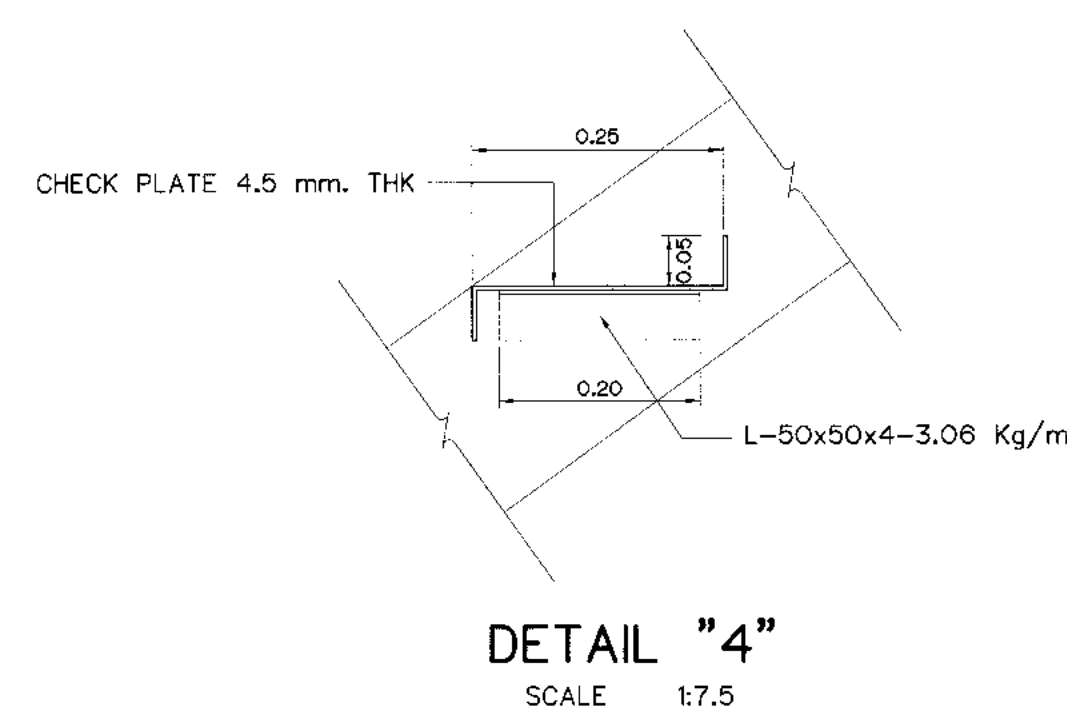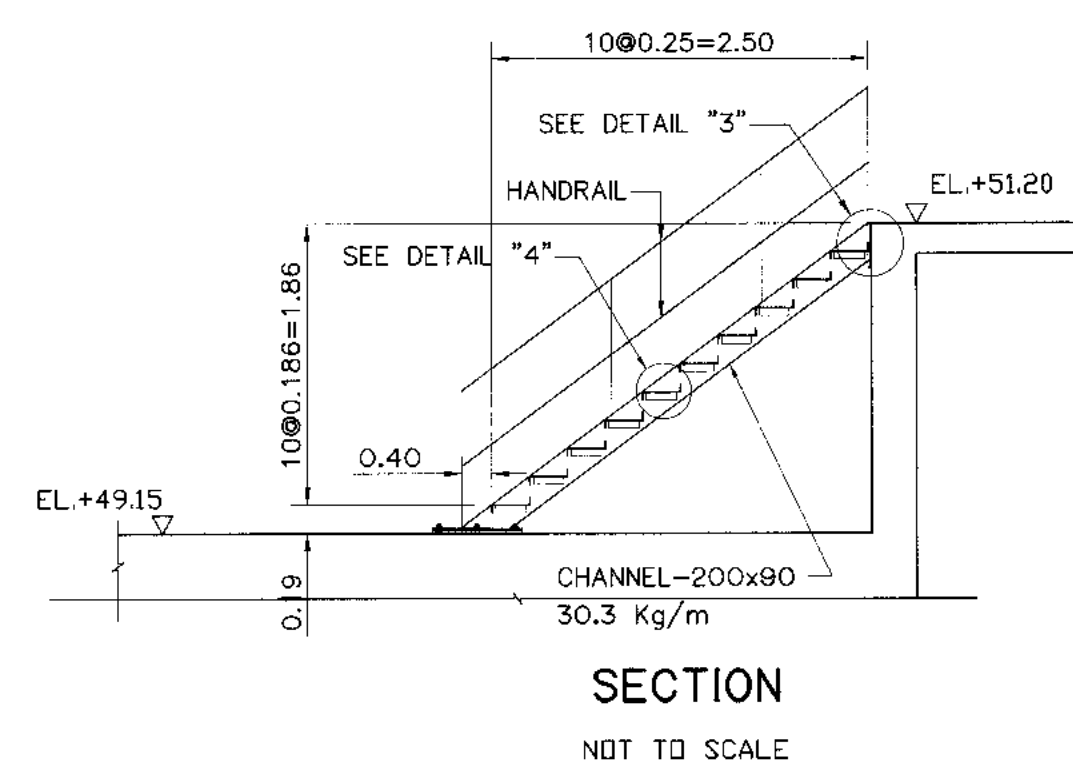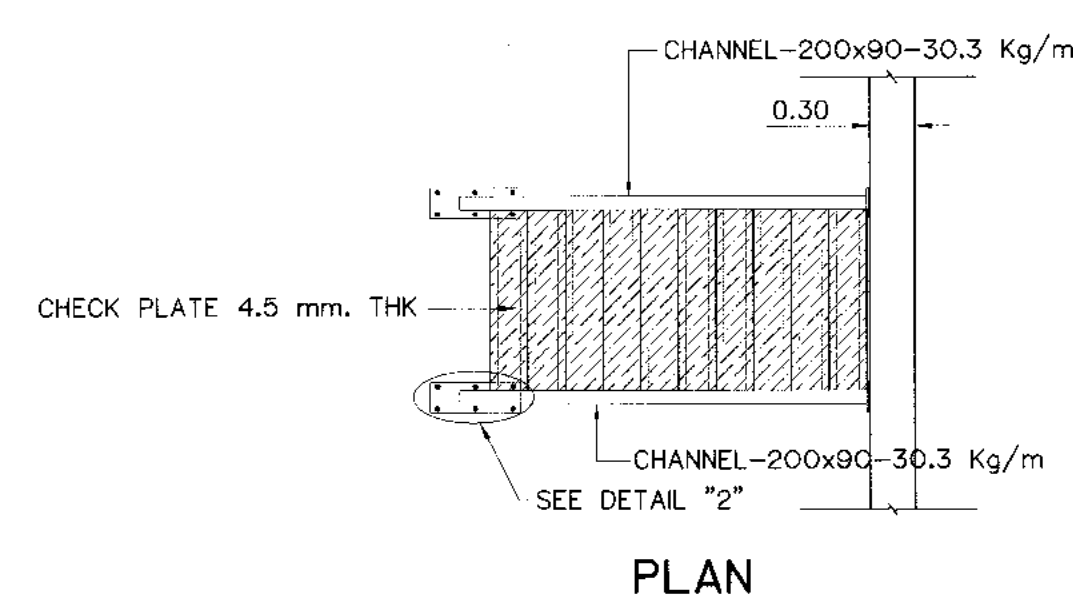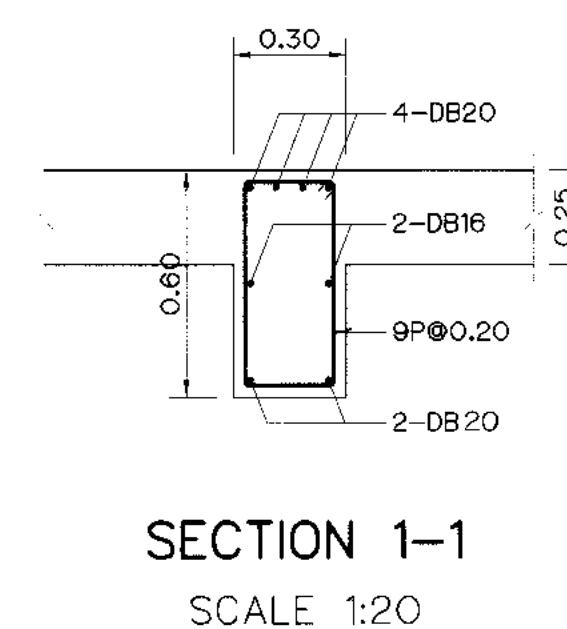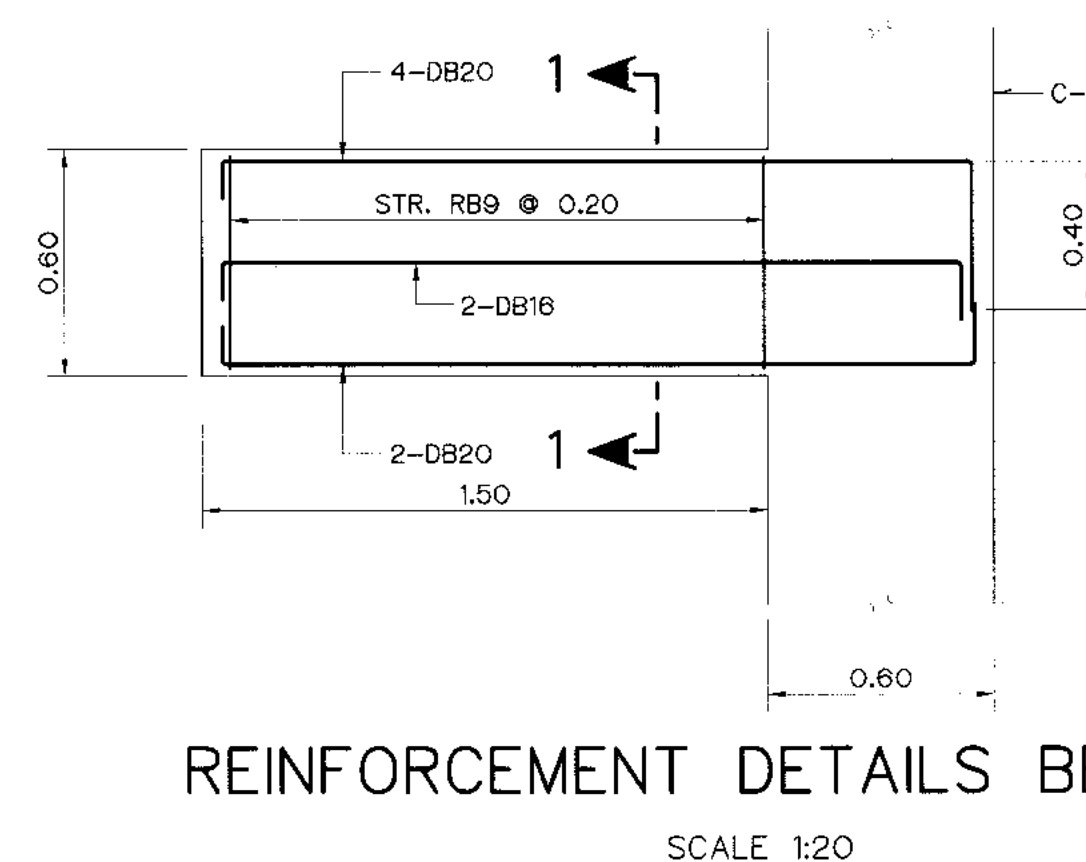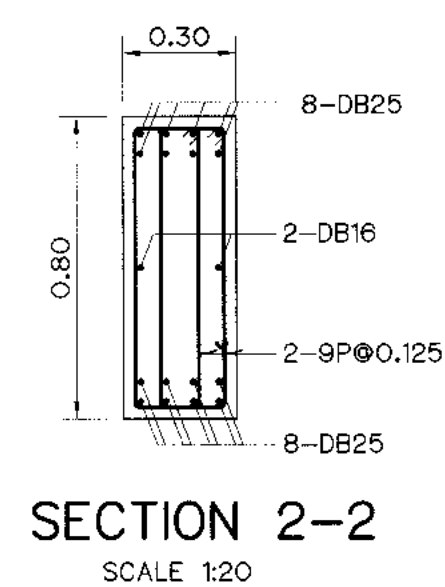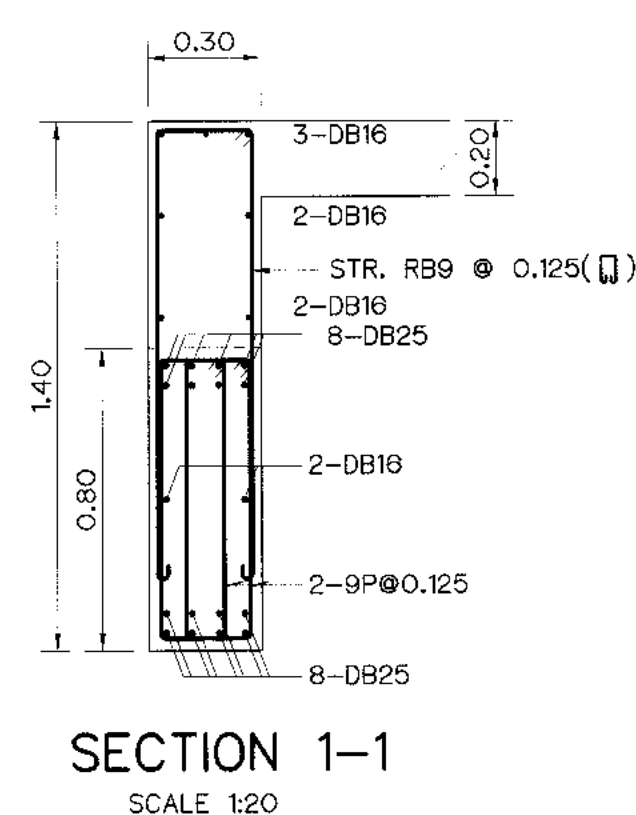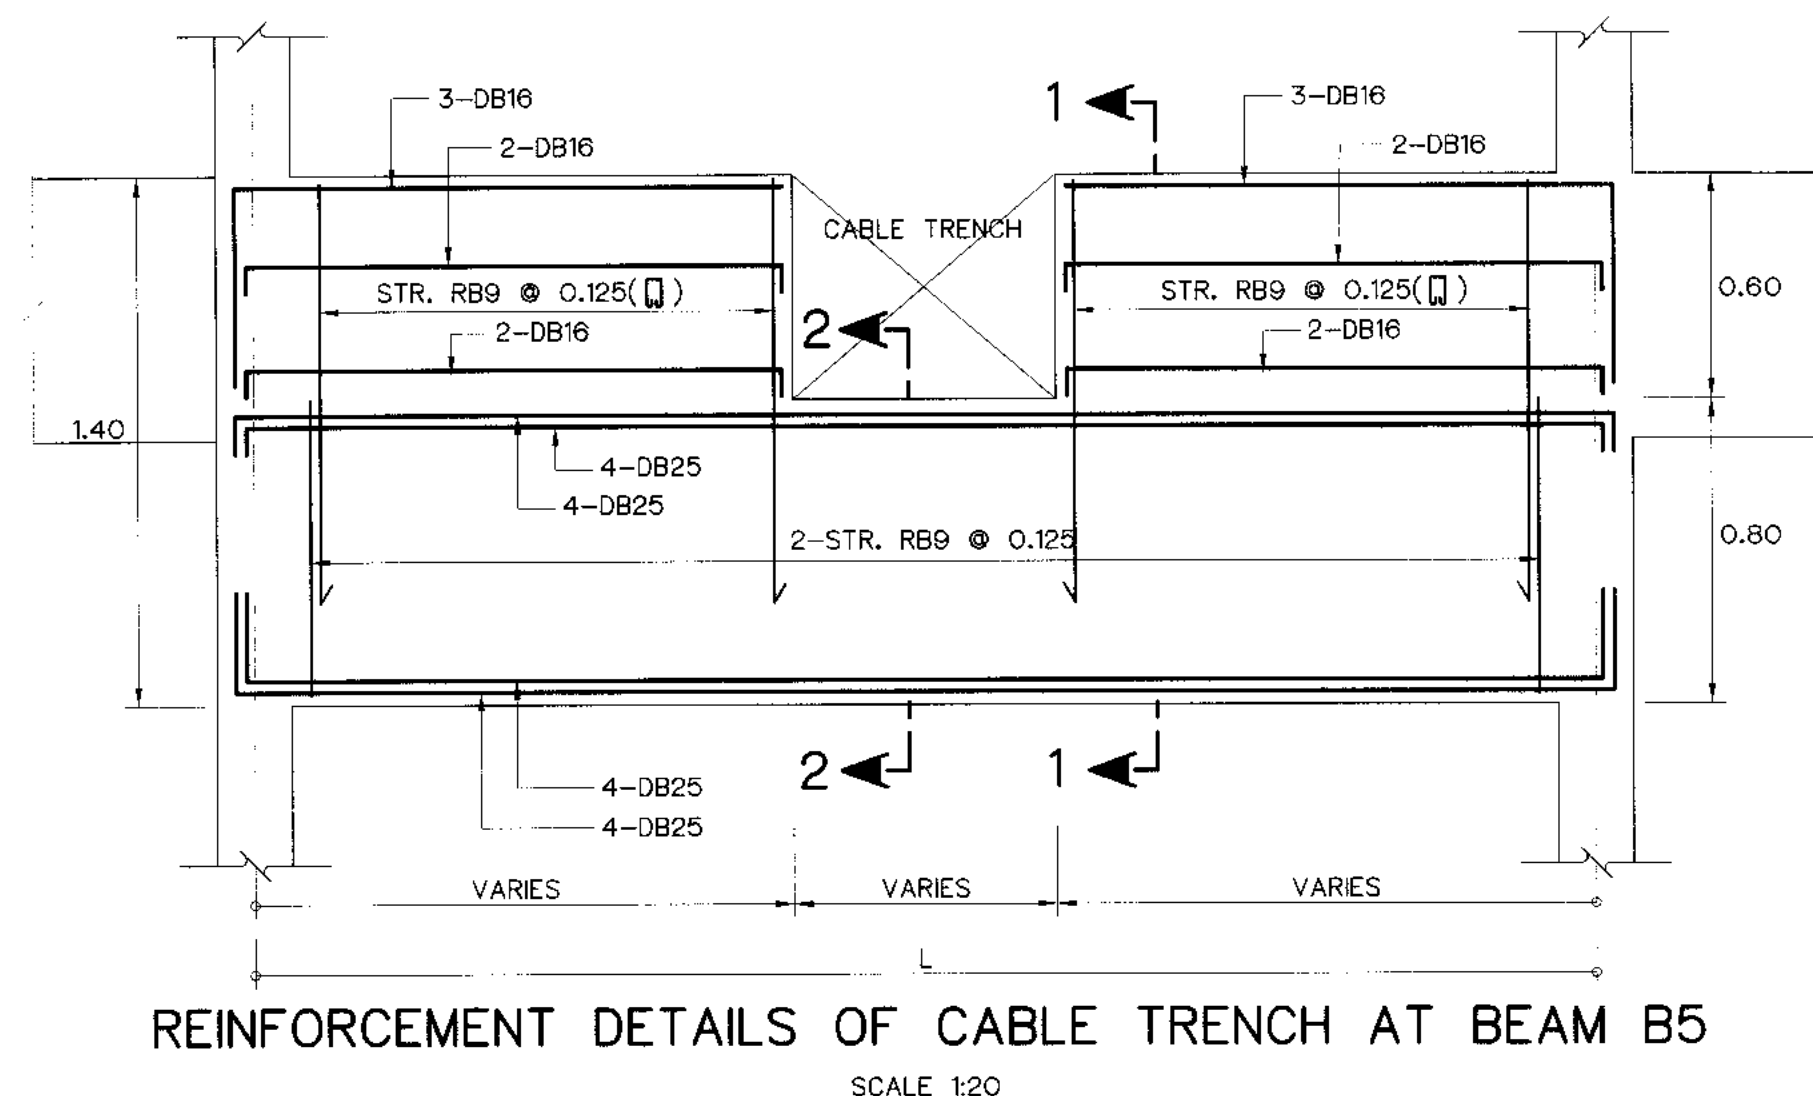





- NOTES :
1. ALL DIMENSIONS AND ELEVATIONS (M.S.L.) ARE IN METERS, UNLESS OTHERWISE SHOWN.
 2. SYMBOLS, ABBREVIATIONS AND GENERAL NOTES SEE DWG. NO. KLP-GN-03
 3. CONCRETE DESIGN BASED ON THE COMPRESSIVE STRENGTH OF 210 KSC, STANDARD CYLINDER Ø0.15x0.30 m. TEST AT AGE 28 DAYS. UNLESS OTHERWISE INDICATED IN SPECIFIC DRAWINGS.

- REFERENCE DRAWINGS :
1. POWERHOUSE, PLAN 1st FLOOR KLP-PH-02
 2. POWERHOUSE, PLAN 2nd AND ROOF PLAN KLP-PH-03

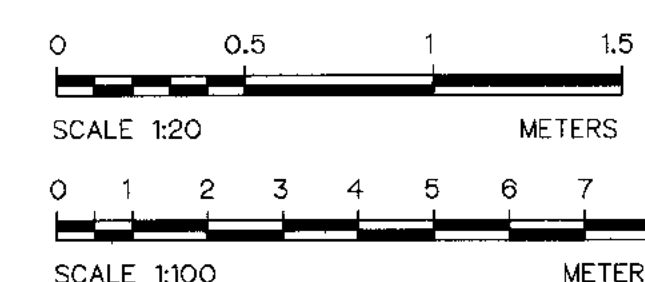


3				
2				
1				
NO.	DATE	REVISIONS	CHECKED	APPROVED

KINGDOM OF THAILAND Department of Alternative Energy Development and Efficiency MINISTRY OF ENERGY	
KLONG LAM PLOK HYDROPOWER PROJECT	
CIVIL WORKS AND TRANSMISSION LINE POWERHOUSE BEAMS DETAILS AND STEEL STAIR	
P&C MANAGEMENT CO.,LTD. DESIGNED: 28.29074 DRAWN: 28.6226 CHECKED: 28.6226 PROJECT MANAGER: 08/03/2559	REVIEWED: 28.6226 SUBMITTED: 28.6226 RECOMMENDED: 28.6226 APPROVED: 28.6226 DRAWING NO. KLP-PH-13 SHEET NO. 85 OF 110

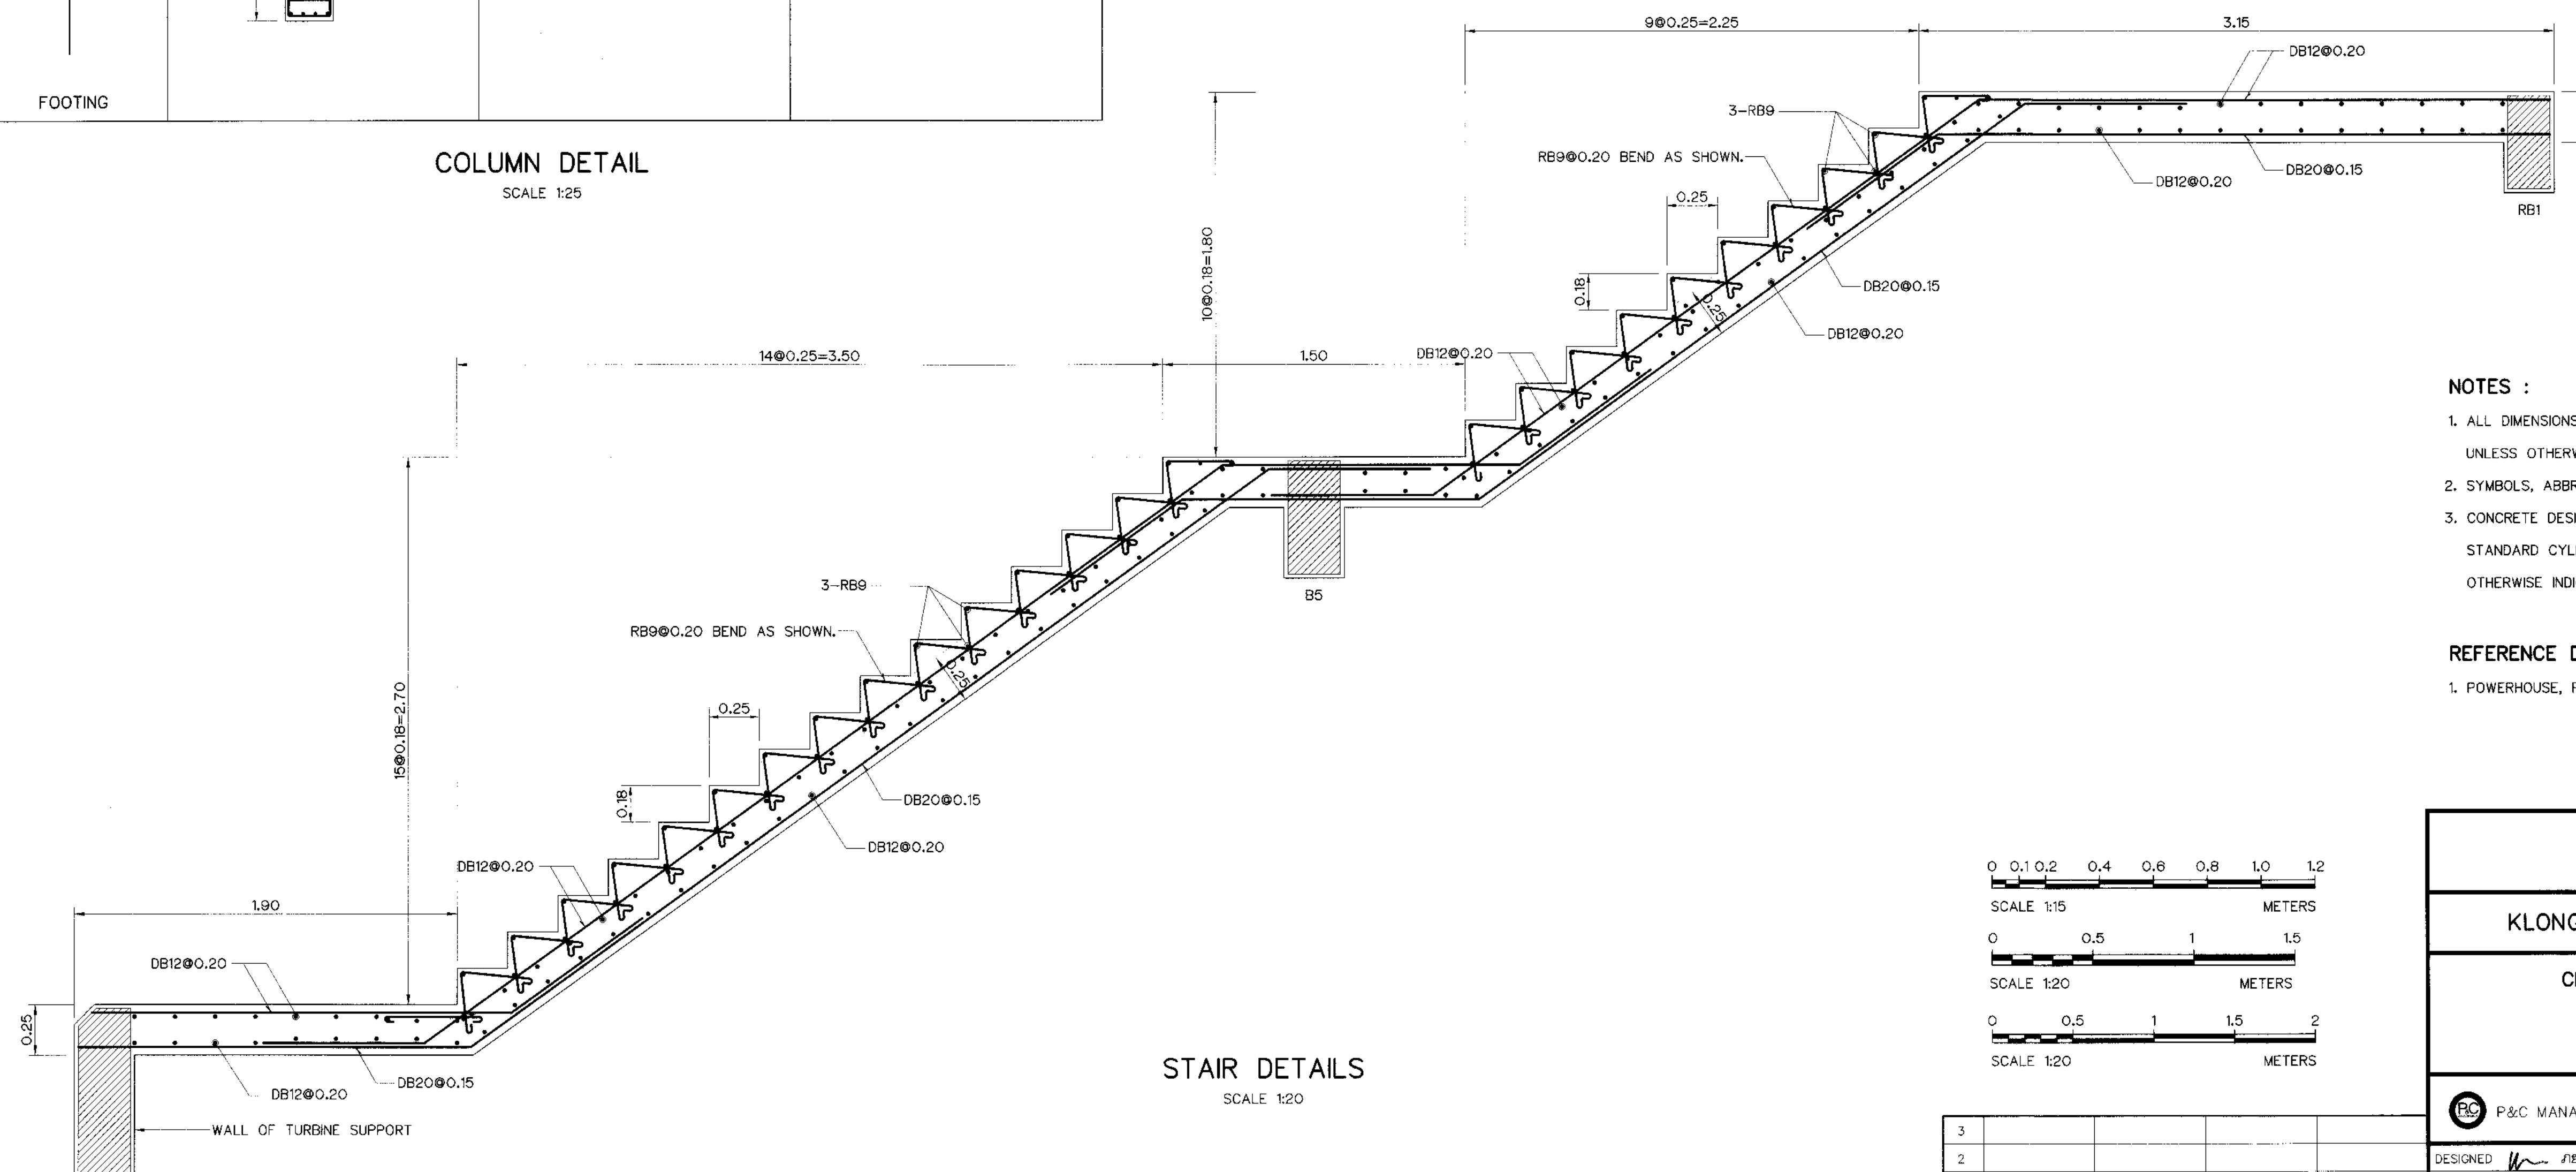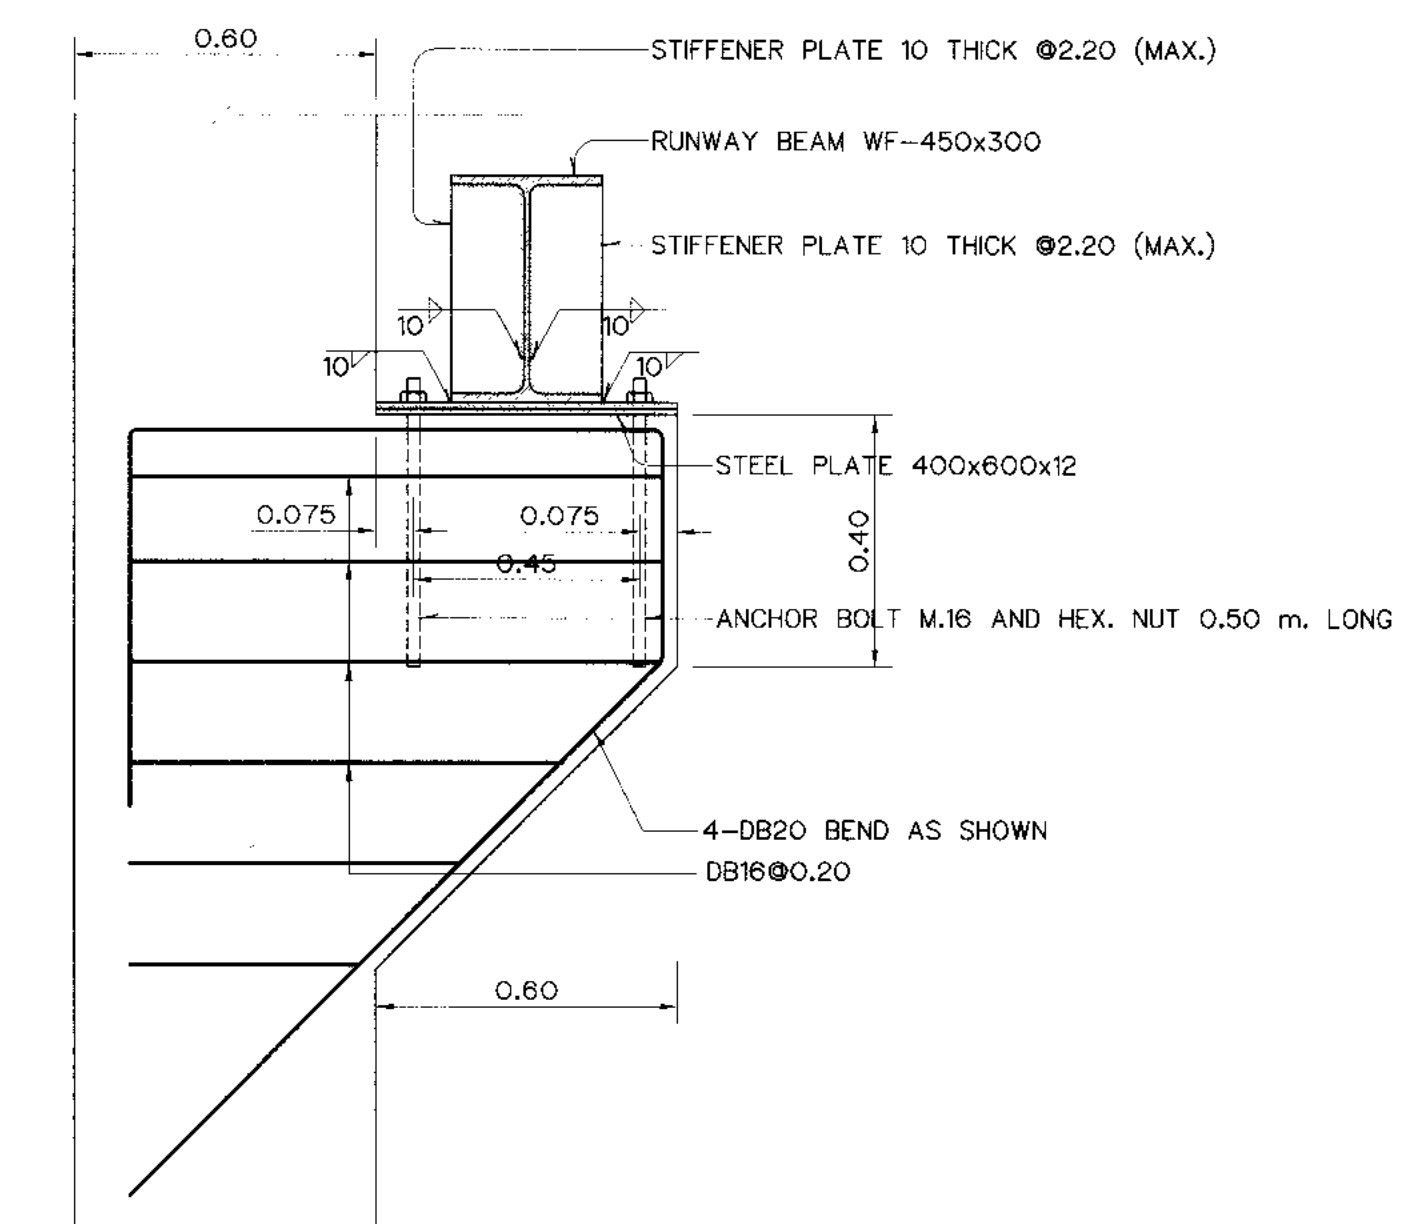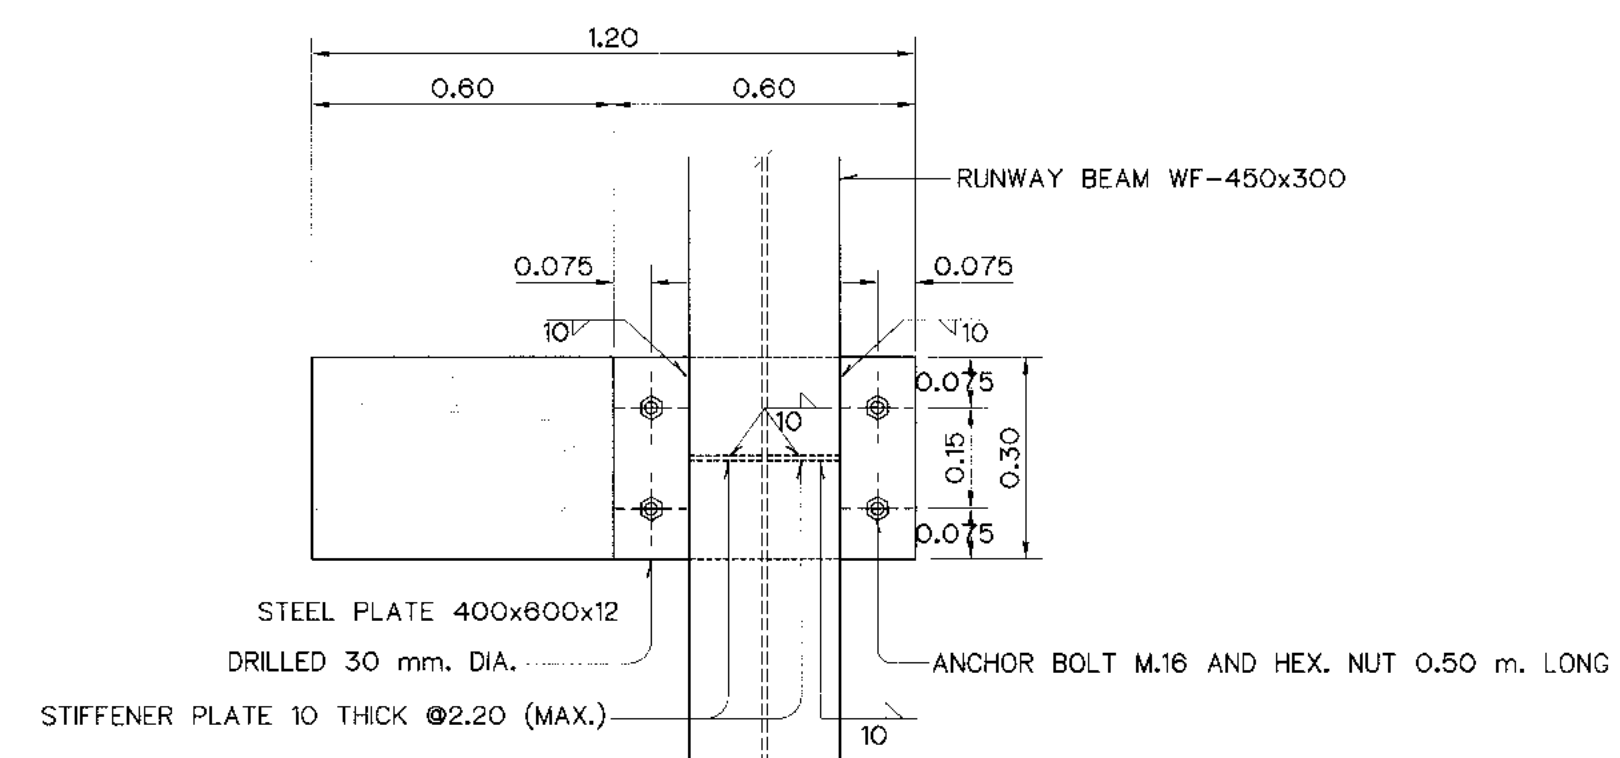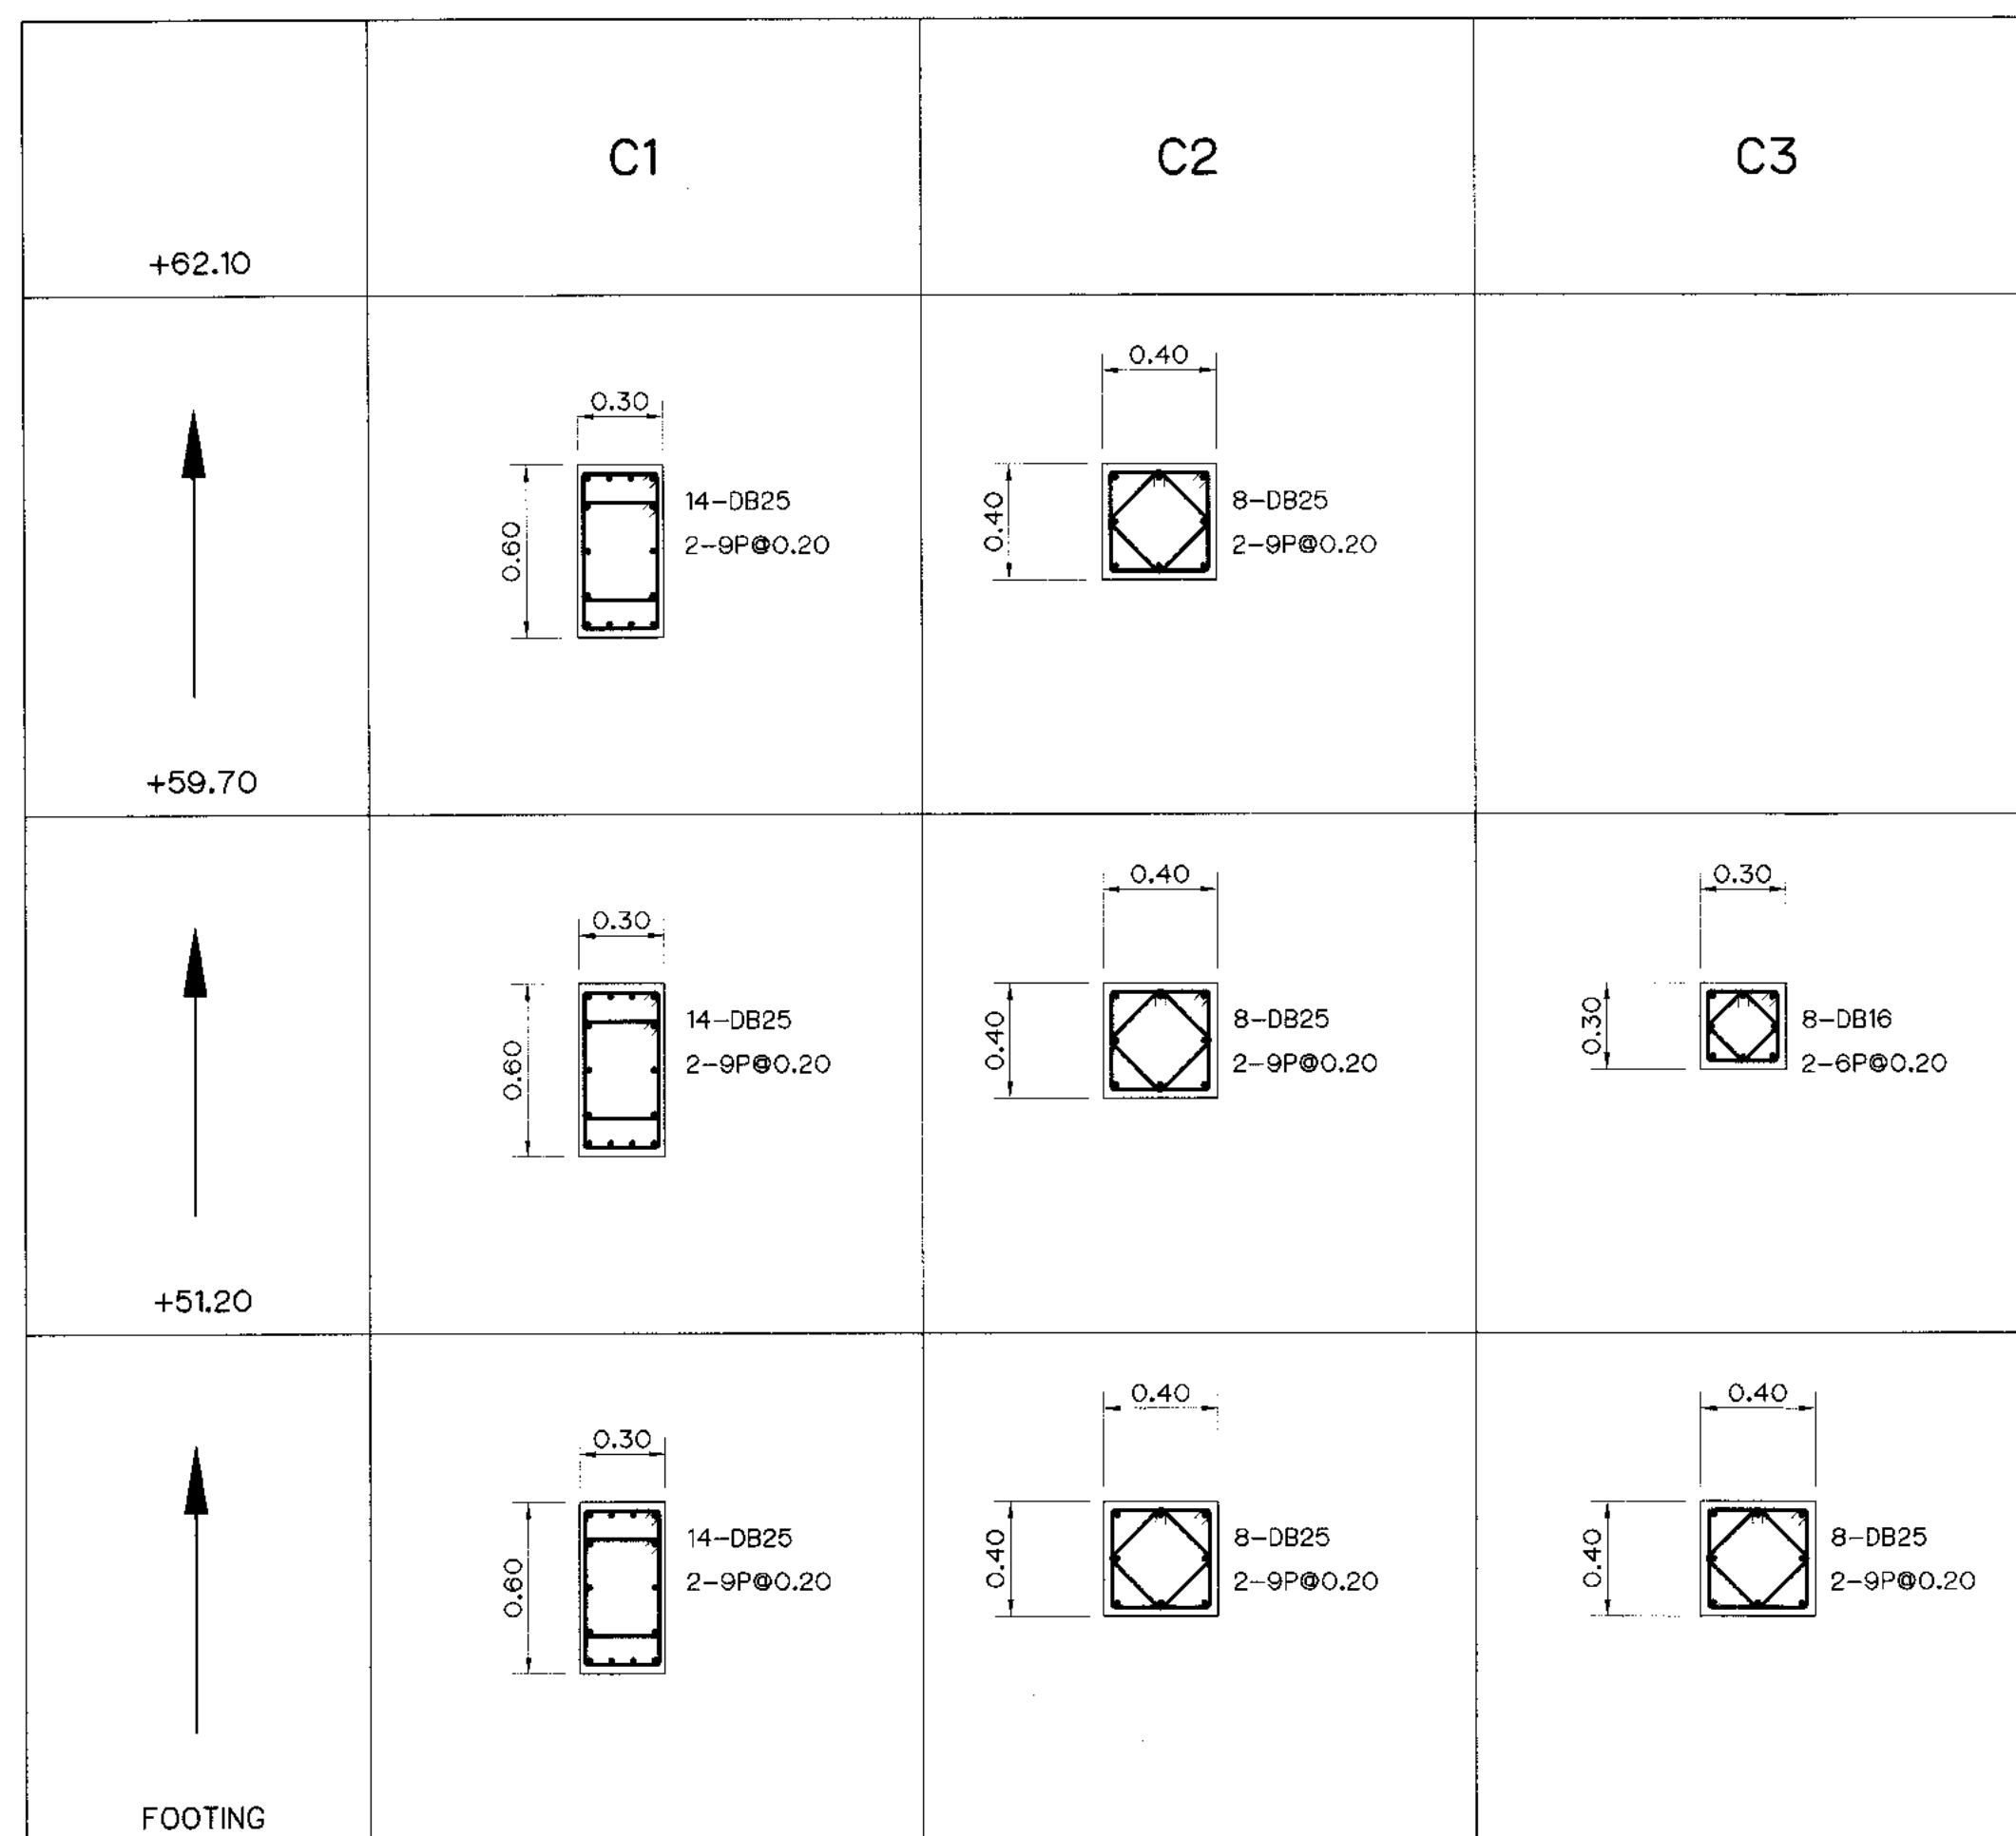


- NOTES :**
1. ALL DIMENSIONS AND ELEVATIONS (M.S.L.) ARE IN METERS,
UNLESS OTHERWISE SHOWN.
 2. SYMBOLS, ABBREVIATIONS AND GENERAL NOTES SEE DWG. NO. KLP-GN-03
 3. CONCRETE DESIGN BASED ON THE COMPRESSIVE STRENGTH OF 210 KSC,
STANDARD CYLINDER $\phi 0.15 \times 0.30$ m. TEST AT AGE 28 DAYS. UNLESS
OTHERWISE INDICATED IN SPECIFIC DRAWINGS.


- REFERENCE DRAWINGS :**
1. POWERHOUSE, PLAN OF SLAB AND DETAILS KLP-PH-10

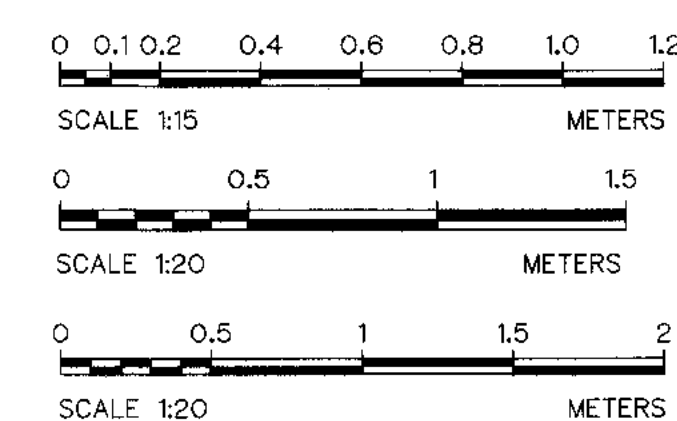


					 P&C MANAGEMENT CO.,LTD.	 MINISTRY OF ENERGY			
3						REVIEWED 			
2						DESIGNED  J18.29074  J18.6226	SUBMITTED  <i>Chamit</i>		
1						DRAWN 	RECOMMENDED 		
NO.	DATE	REVISIONS	CHECKED	APPROVED	CHECKED  J18.6226	APPROVED  P. Harnsiri			
CONSULTANTS					DEDE			DRAWING NO. KLP-PH-14	SHEET NO. 86 of 110
					PROJECT MANAGER	DATE			

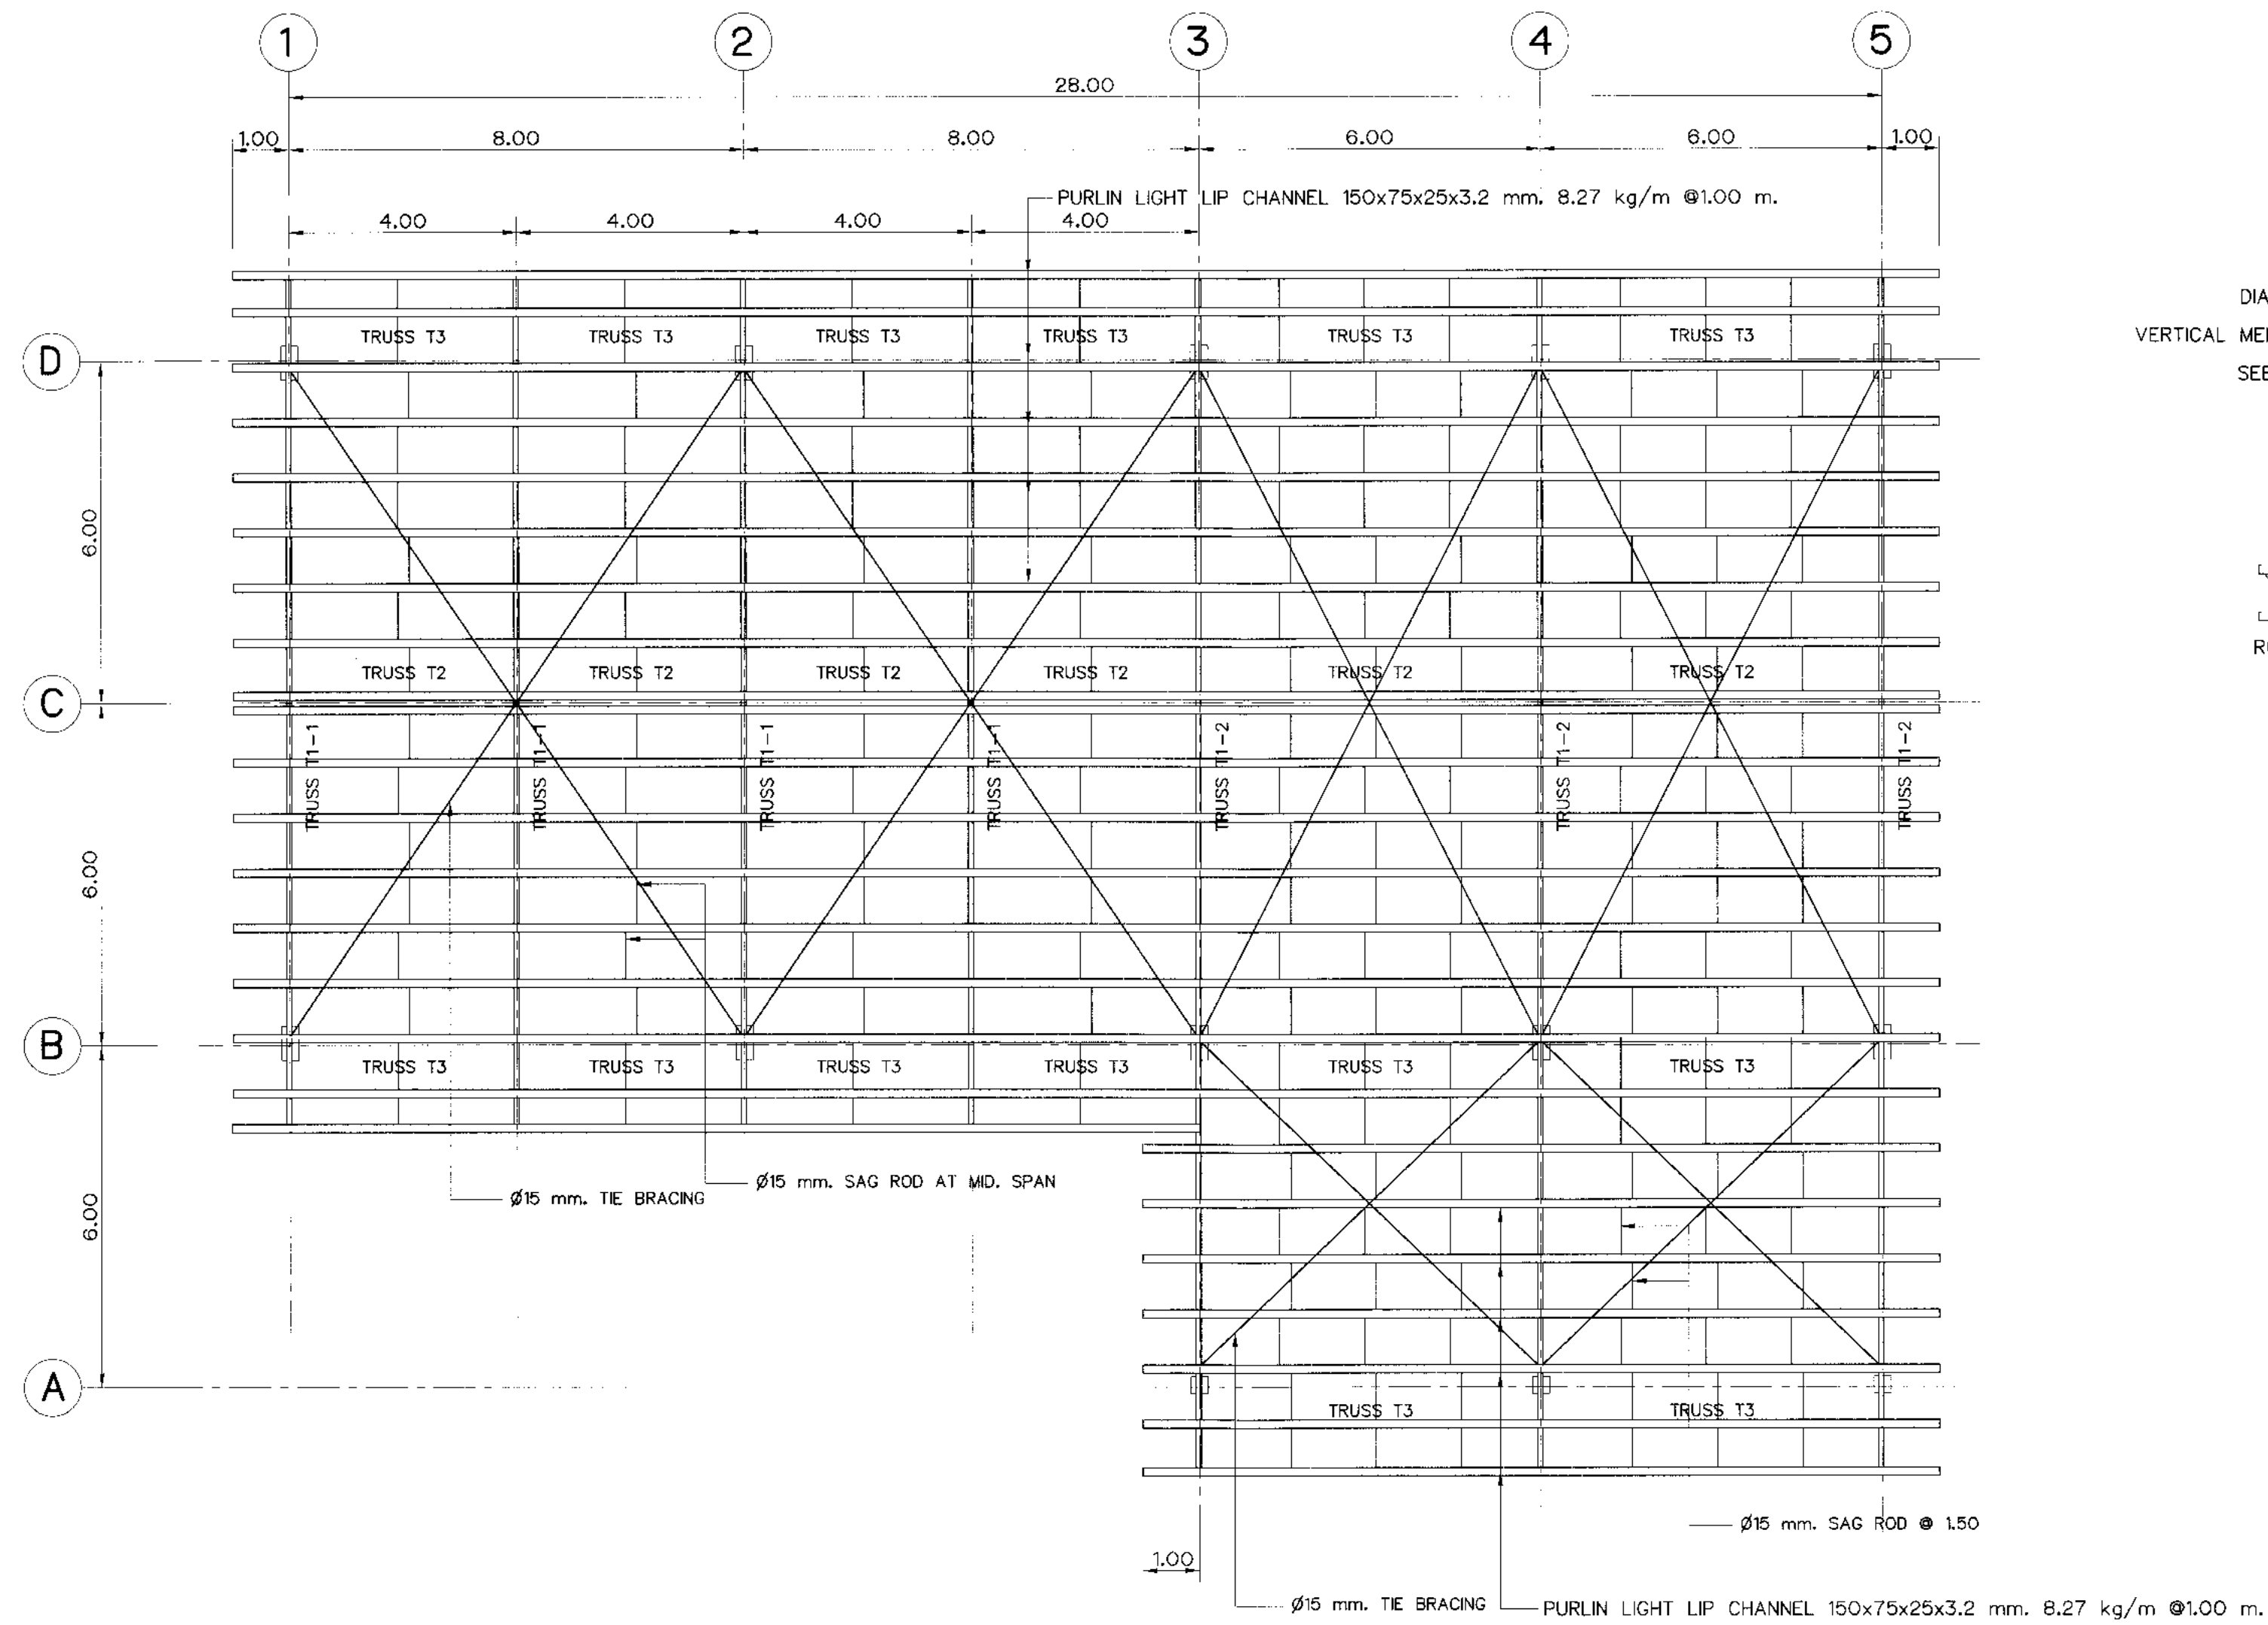


PLAN OF ROOF TRUSSES
SCALE 1:100

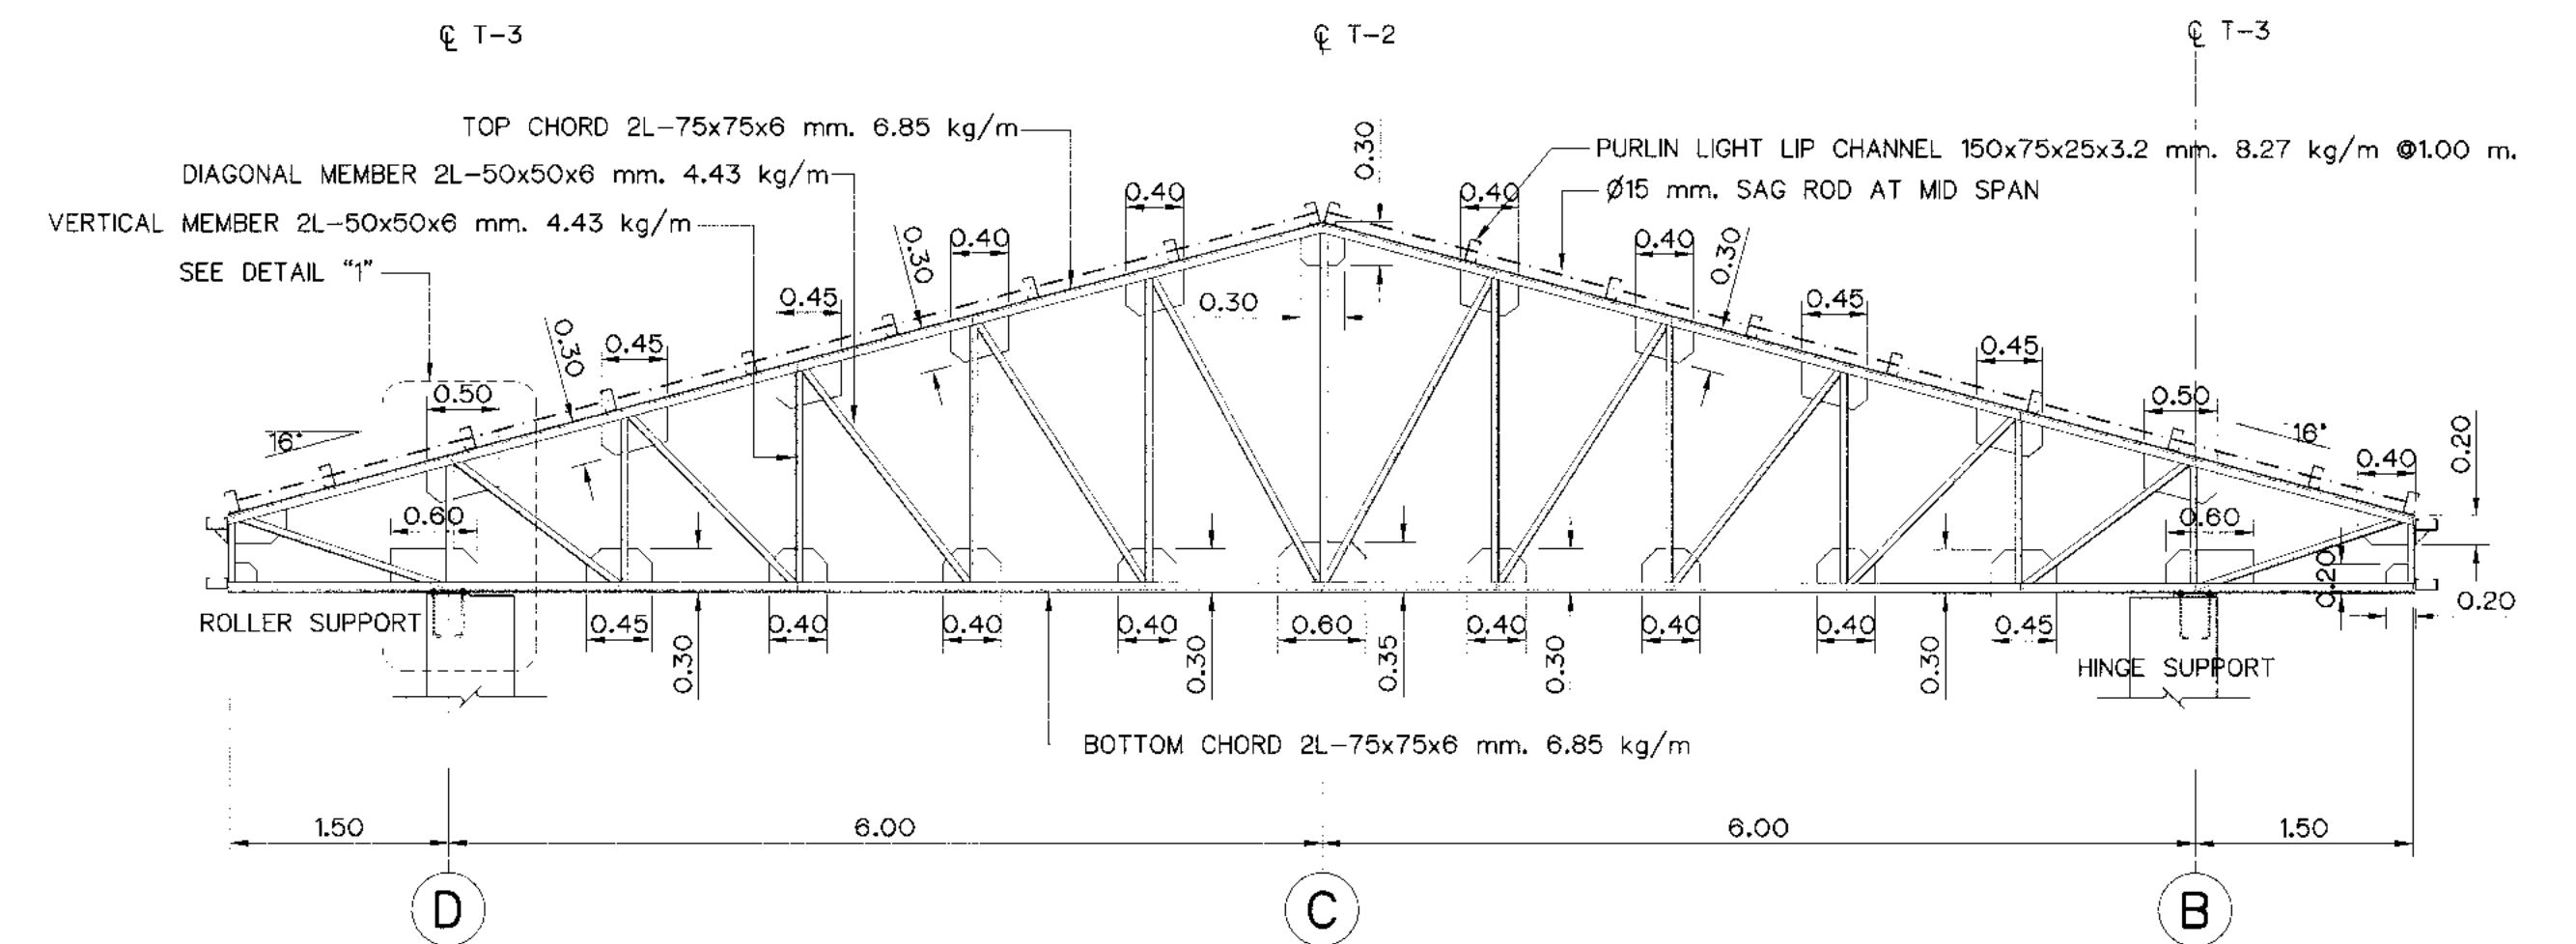


TRUSS T1-1
SCALE 1:50

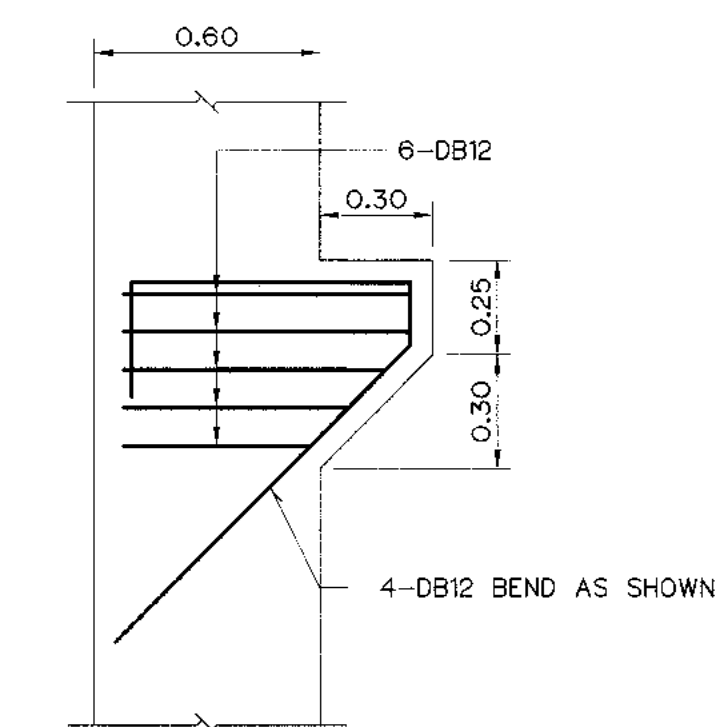

BRACKET DETAIL
SCALE 1:20

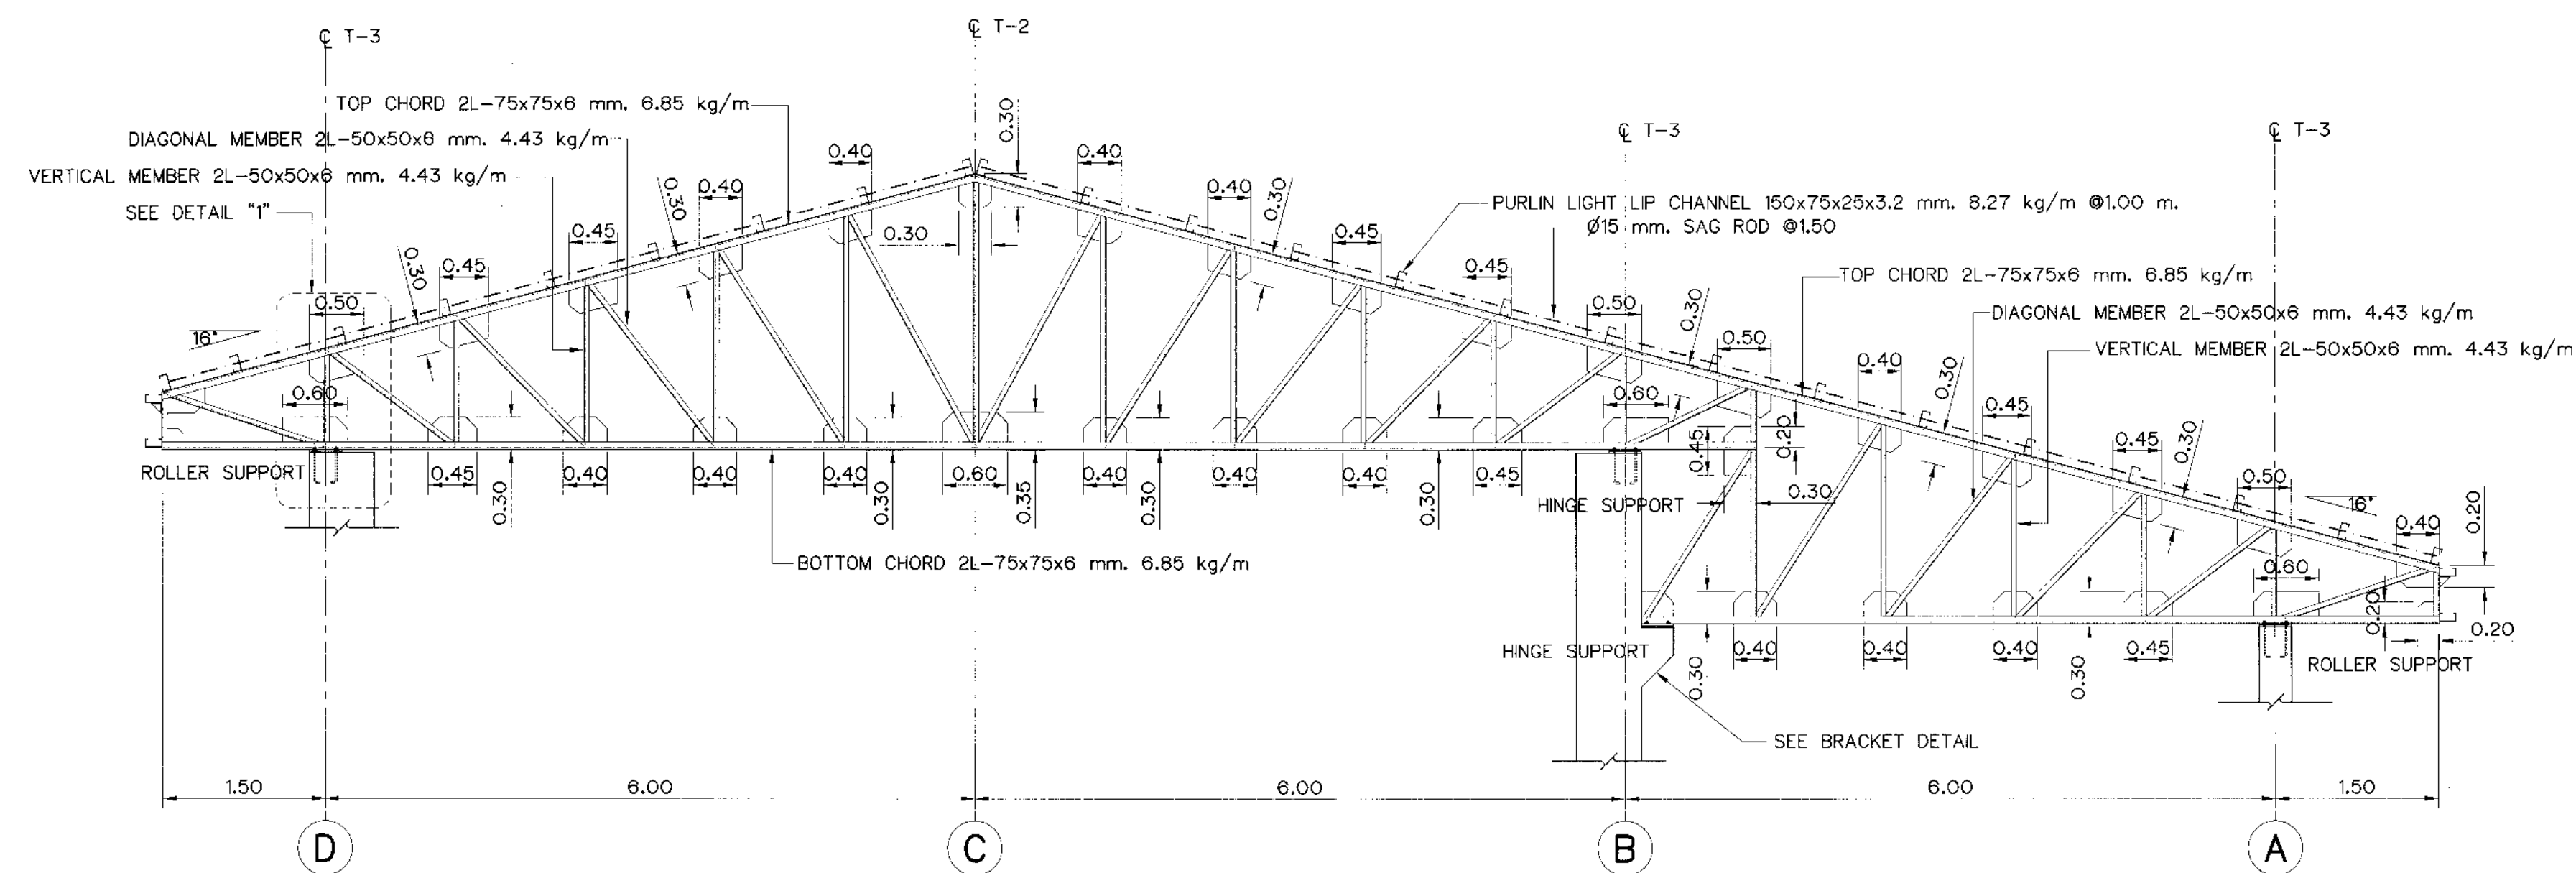


TRUSS T1-2
SCALE 1:50

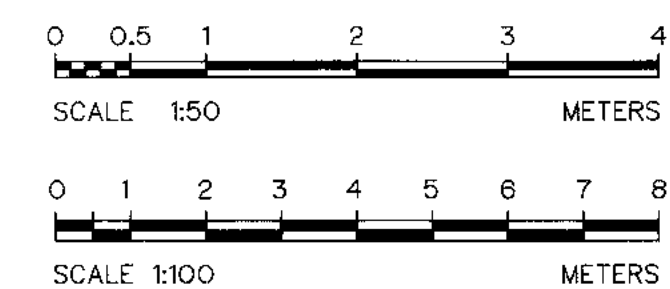


- NOTES :**
1. ALL DIMENSIONS AND ELEVATIONS (M.S.L.) ARE IN METERS, UNLESS OTHERWISE SHOWN.
 2. SYMBOLS, ABBREVIATIONS AND GENERAL NOTES SEE DWG. NO. KLP-GN-03

- REFERENCE DRAWINGS :**
1. POWERHOUSE, PLAN 1st FLOOR KLP-PH-02
 2. POWERHOUSE, PLAN OF SLAB AND DETAILS KLP-PH-10
 3. DETAILS TRUSS T-1 AND T-3 (1/2) KLP-PH-13


KINGDOM OF THAILAND Department of Alternative Energy Development and Efficiency MINISTRY OF ENERGY	
KLONG LAM PLOK HYDROPOWER PROJECT	
CIVIL WORKS AND TRANSMISSION LINE POWERHOUSE ROOF BEAM AND TRUSS PLANS	
P&C MANAGEMENT CO., LTD. DESIGNED <i>[Signature]</i> 20.29074 20.6226 DRAWN <i>[Signature]</i> NO. DATE REVISIONS CHECKED APPROVED	REVIEWED <i>[Signature]</i> SUBMITTED <i>[Signature]</i> RECOMMENDED <i>[Signature]</i> APPROVED <i>[Signature]</i> PROJECT MANAGER DATE
CONSULTANTS DEDE	DRAWING NO. KLP-PH-15 SHEET NO. 87 OF 110

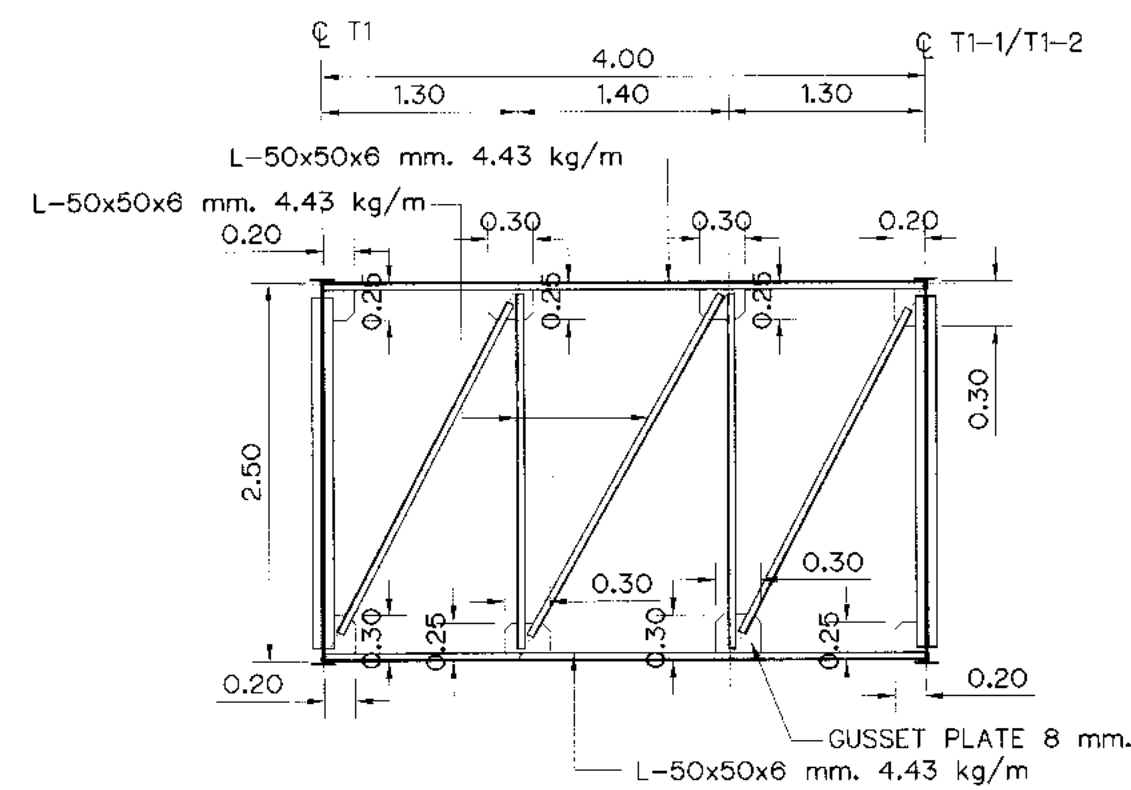


TRUSS T2 (SPAN 4.00m.)
SCALE 1:50

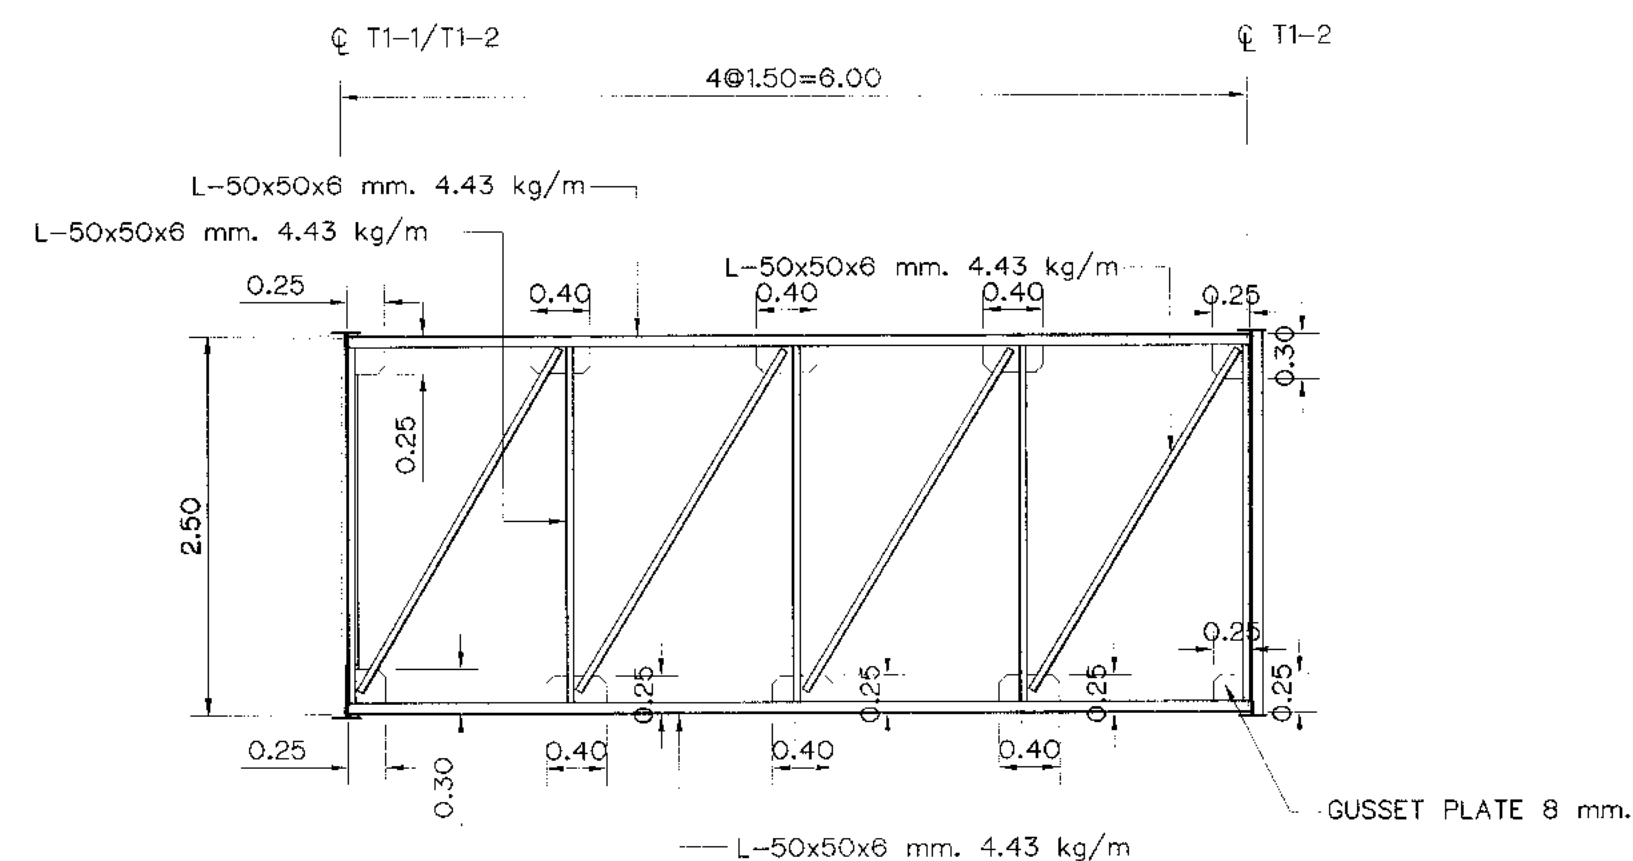

TRUSS T2 (SPAN 6.00m.)
SCALE 1:50

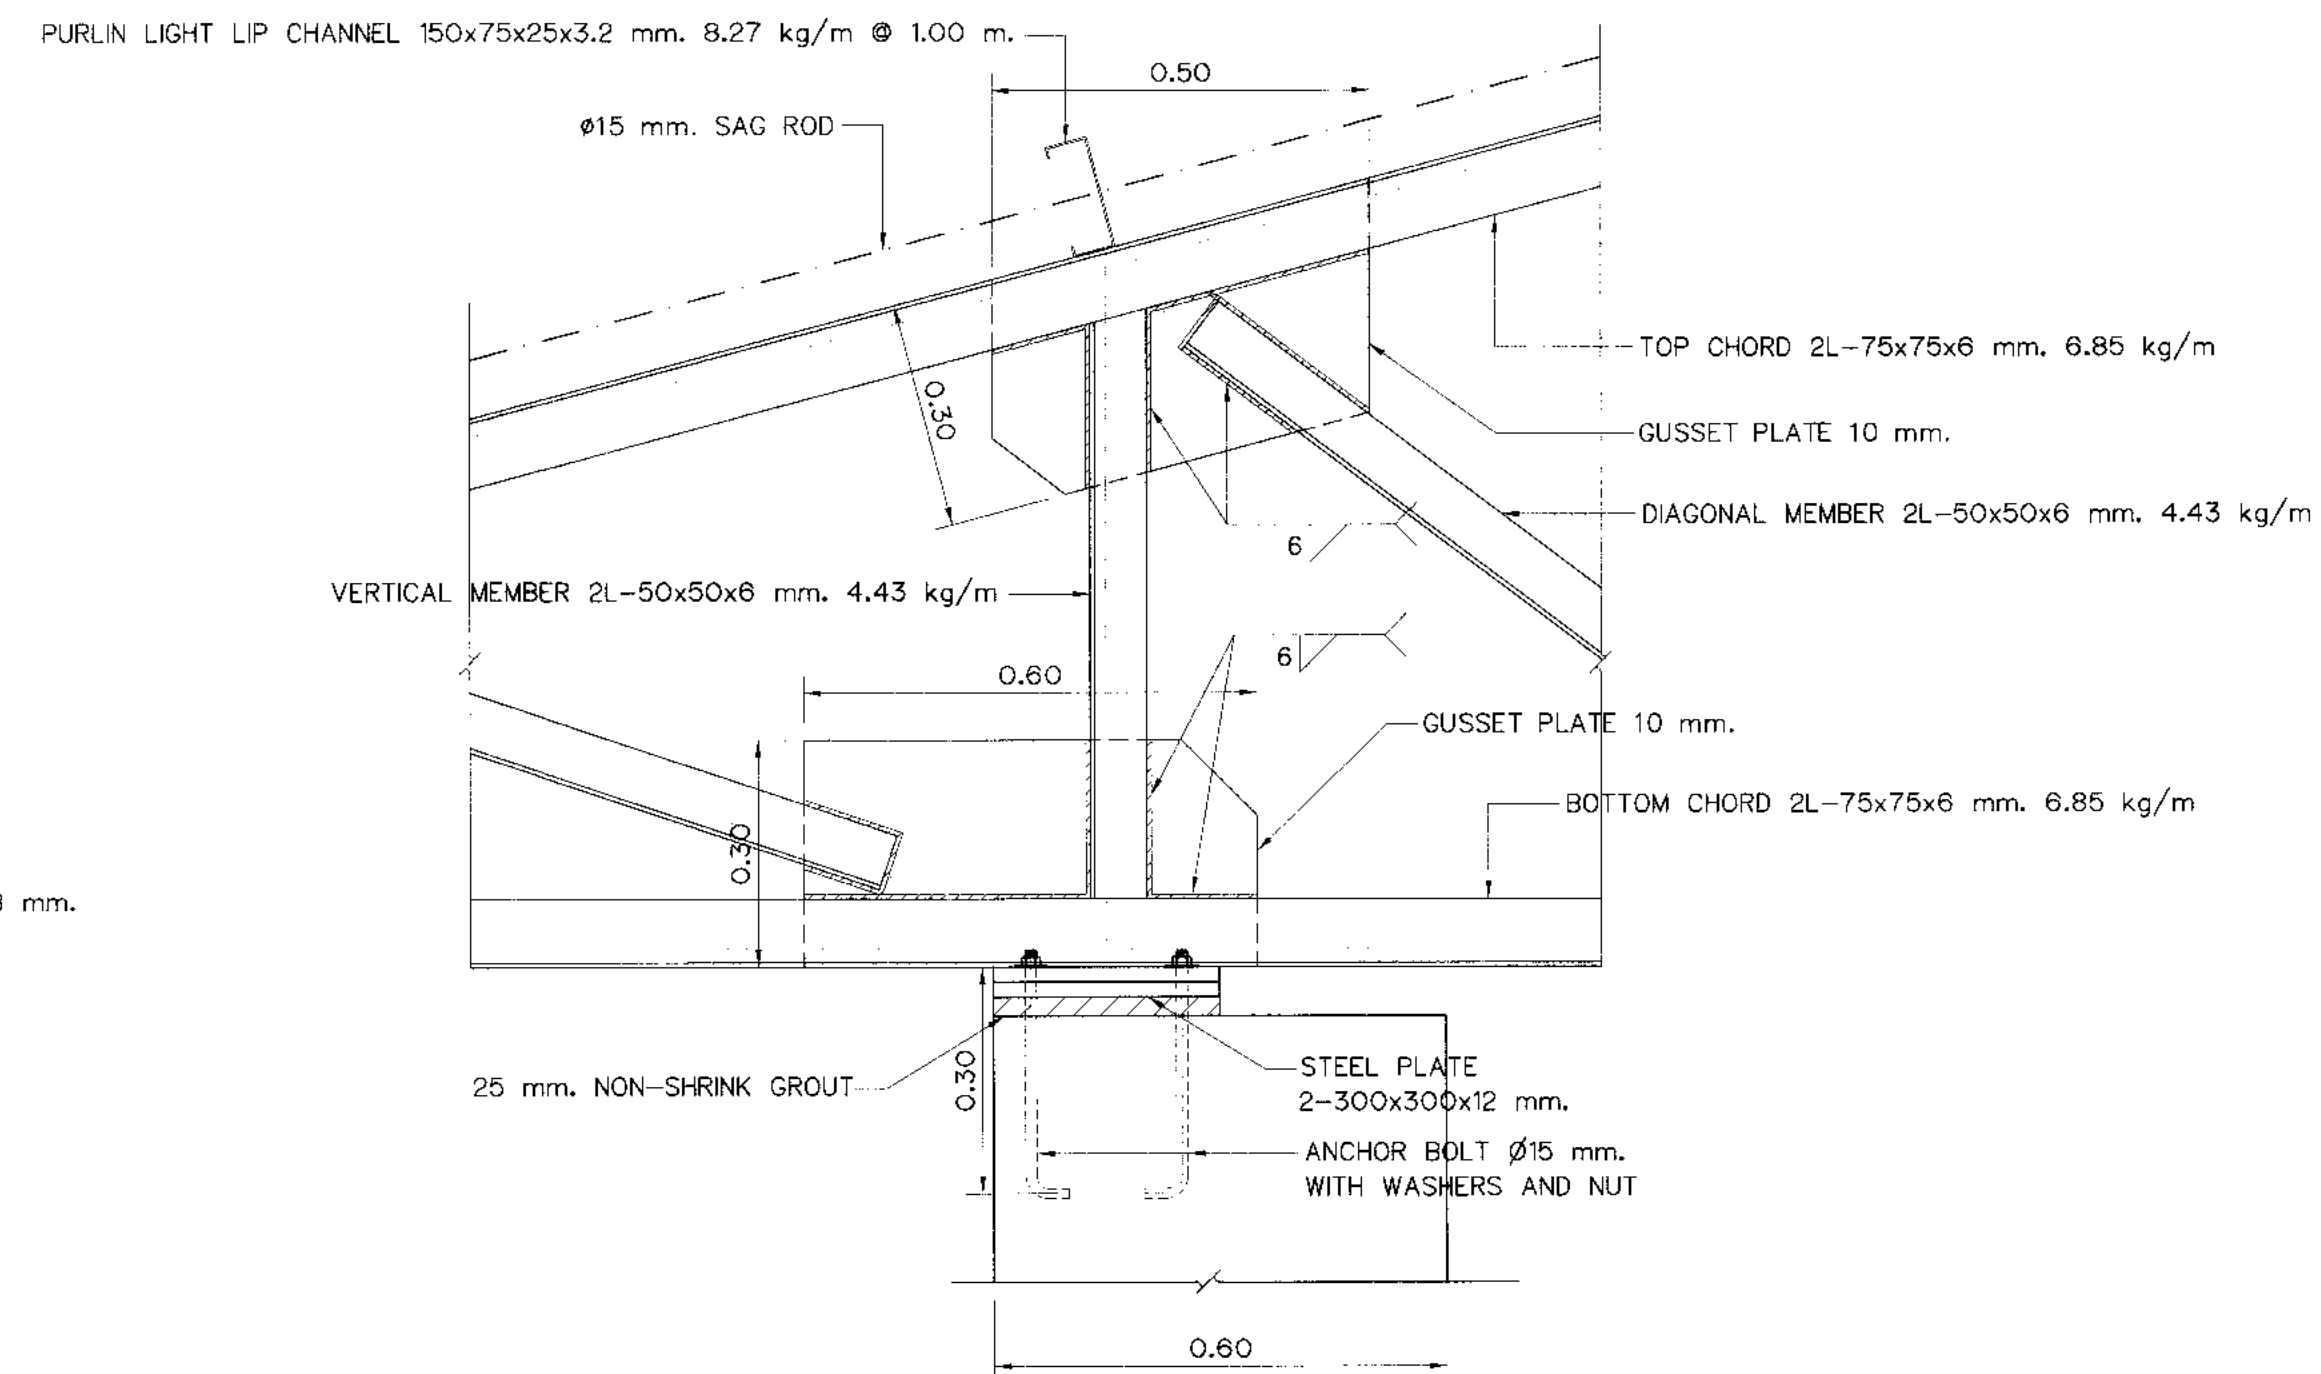

DETAILS "1" (ON COLUMN)
SCALE 1:20

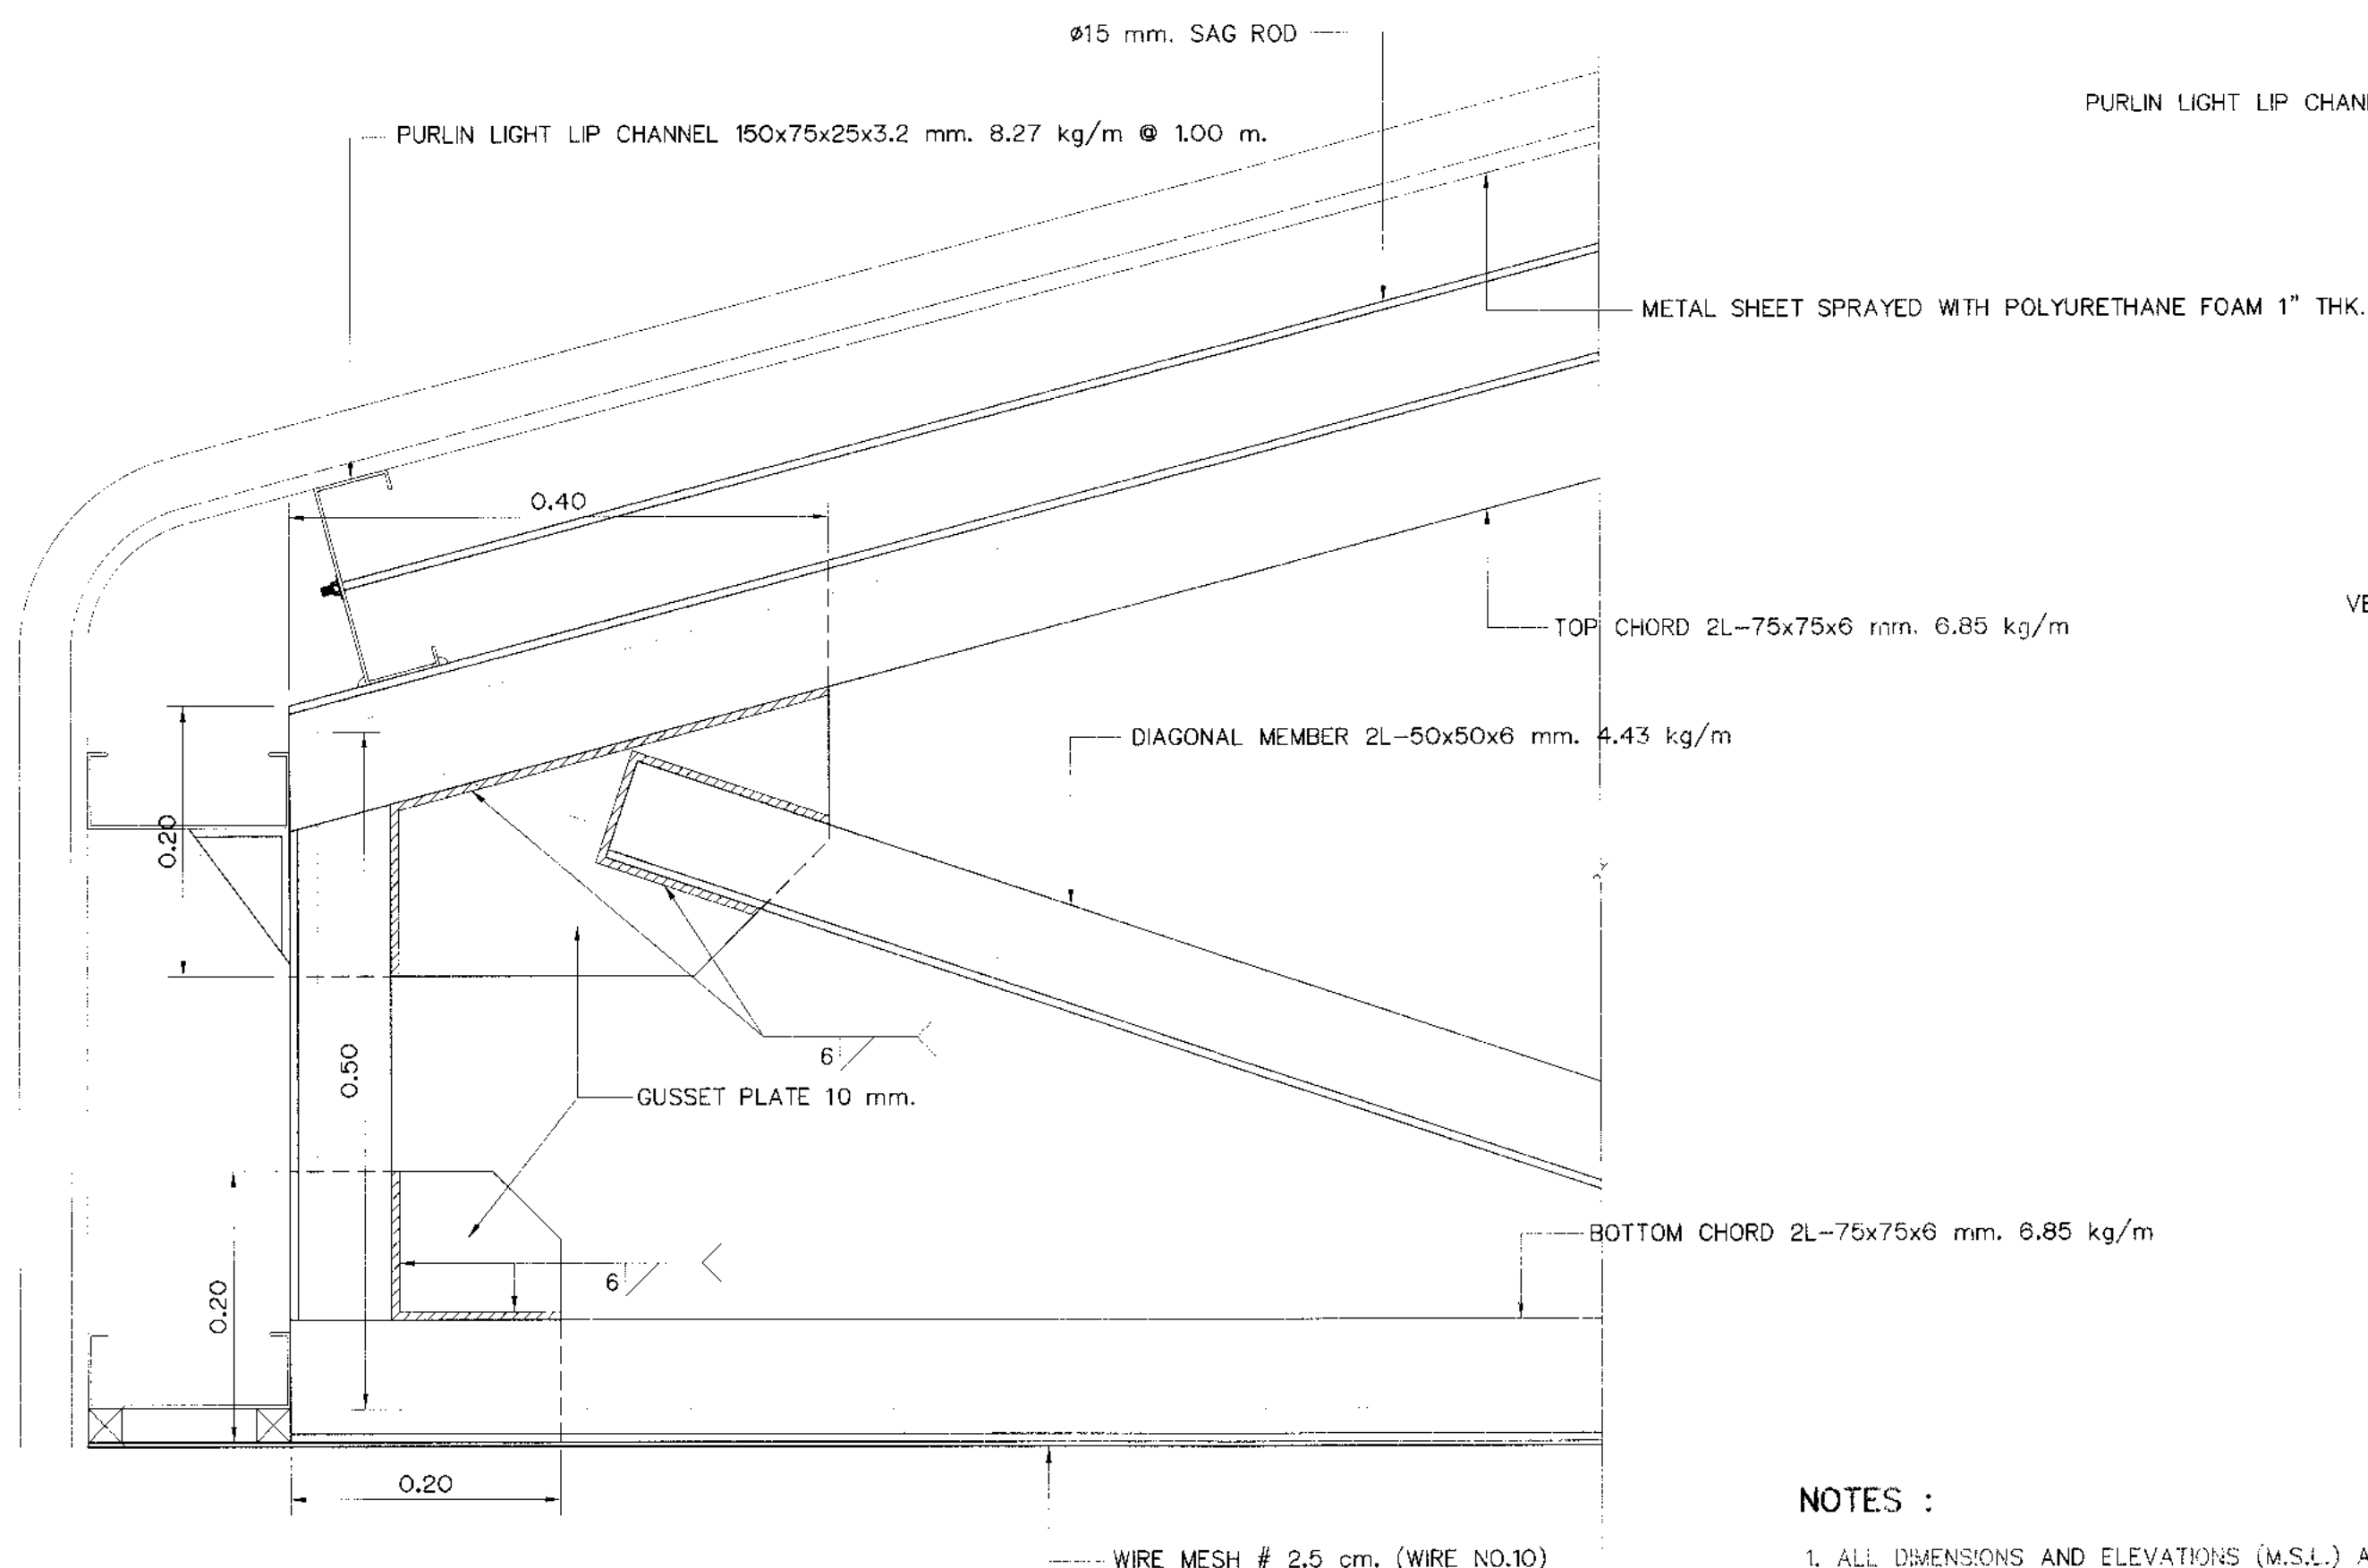

EAVES DETAIL
SCALE 1:10


NOTES :

1. ALL DIMENSIONS AND ELEVATIONS (M.S.L.) ARE IN METERS, UNLESS OTHERWISE SHOWN.
2. SYMBOLS, ABBREVIATIONS AND GENERAL NOTES SEE DWG. NO. KLP-GN-03
3. WELDING CONNECTION USE 6 MM, UNLESS OTHERWISE SHOWN


REFERENCE DRAWINGS :

1. ROOF BEAM AND TRUSS PLANS
2. TRUSS DETAIL (2/2)




KLP-PH-15
KLP-PH-17

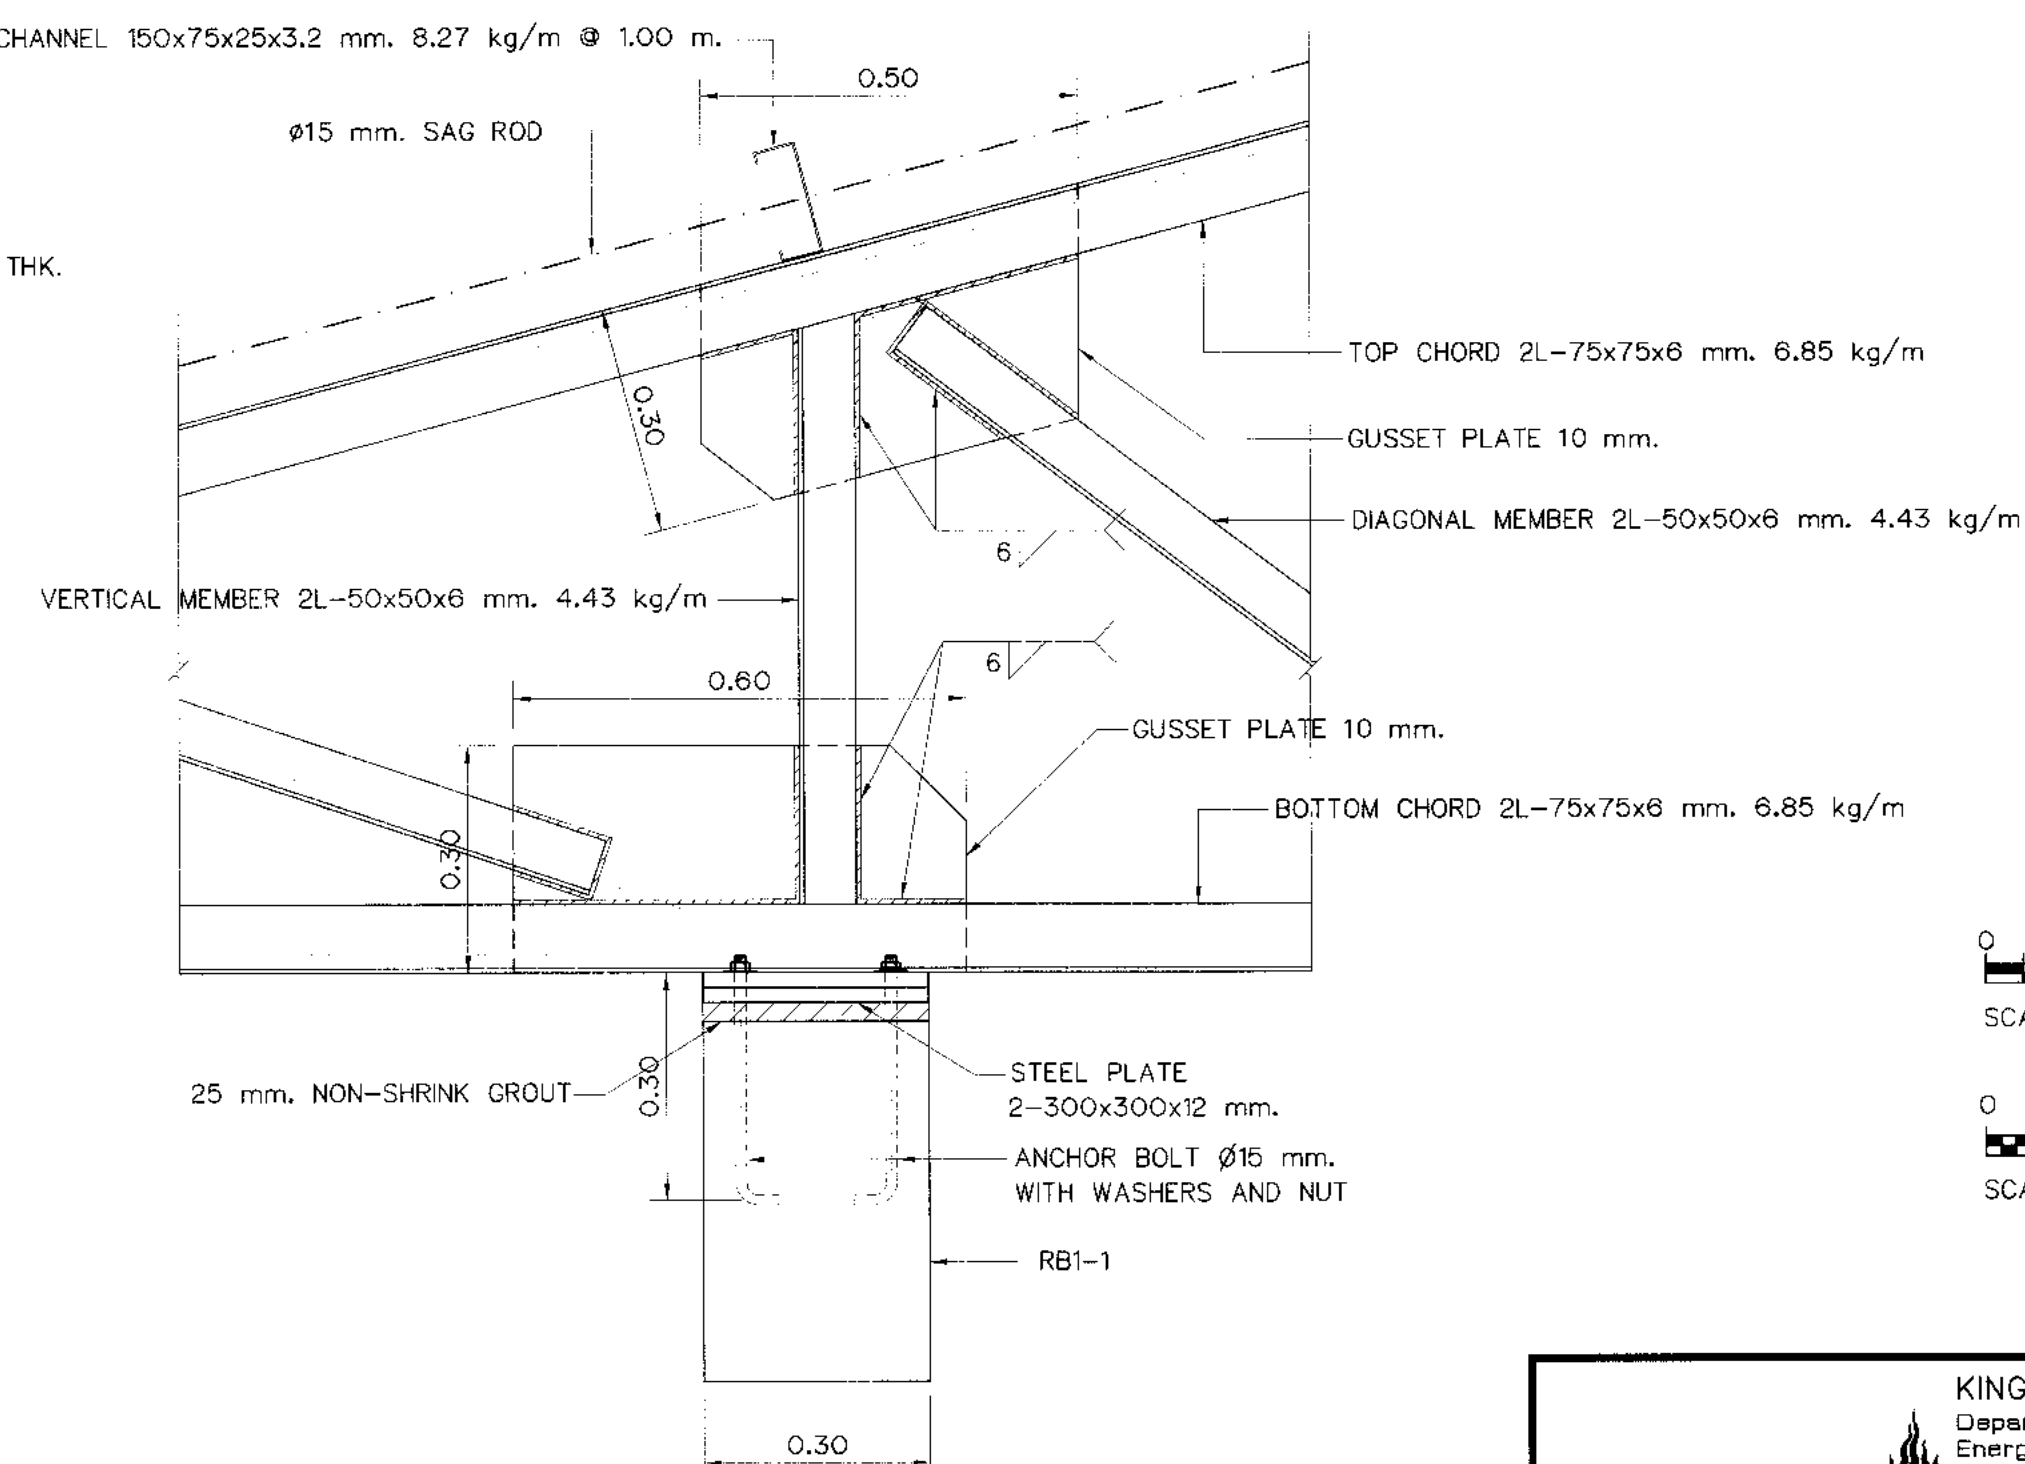


DETAILS "1" (ON BEAM)
SCALE 1:20

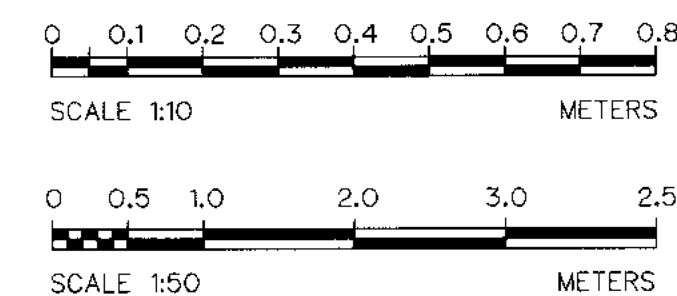


 KINGDOM OF THAILAND Department of Alternative Energy Development and Efficiency MINISTRY OF ENERGY	
KLONG LAM PLOK HYDROPOWER PROJECT	
CIVIL WORKS AND TRANSMISSION LINE POWERHOUSE TRUSS DETAIL (1/2)	
 P&C MANAGEMENT CO., LTD.	 MINISTRY OF ENERGY
DESIGNED <i>W. 18/29074</i> <i>P.V.</i> 28/6/226	REVIEWED <i>Chamit</i>
DRAWN <i>g.m.x</i>	RECOMMENDED <i>P. Hany</i>
CHECKED <i>P.V.</i> 28/6/226	APPROVED <i>P. Hany</i>
 PROJECT MANAGER	 DATE
CONSULTANTS	DEDE
3 2 1 NO. DATE REVISIONS CHECKED APPROVED	88 OF 110

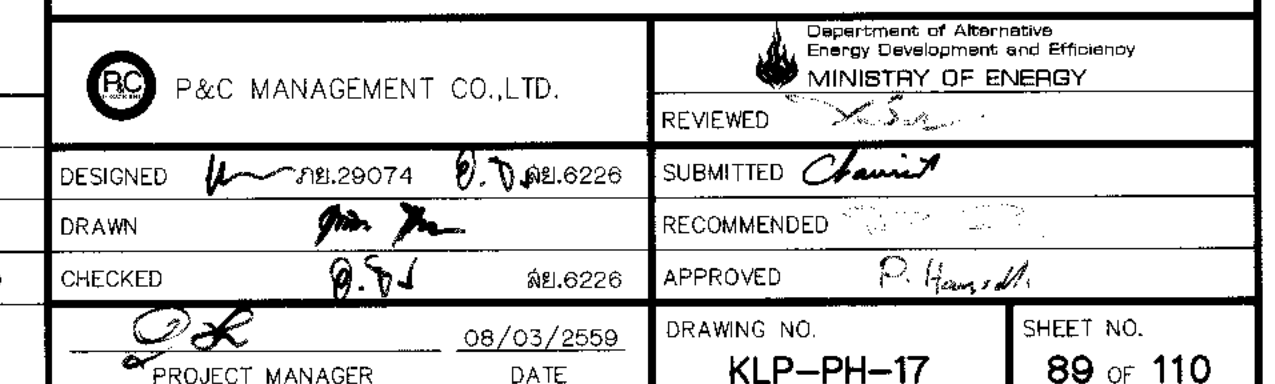  


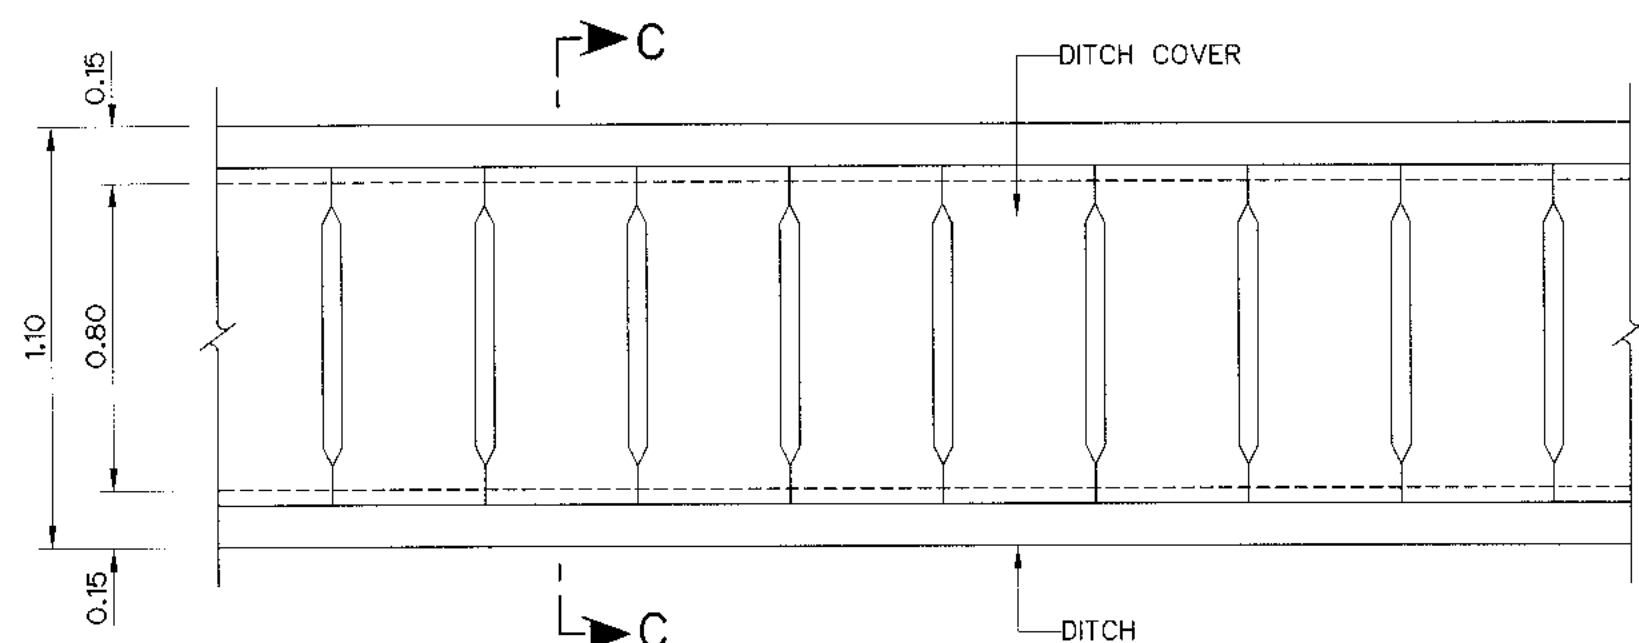


DITCH PLAN
NOT TO SCALE

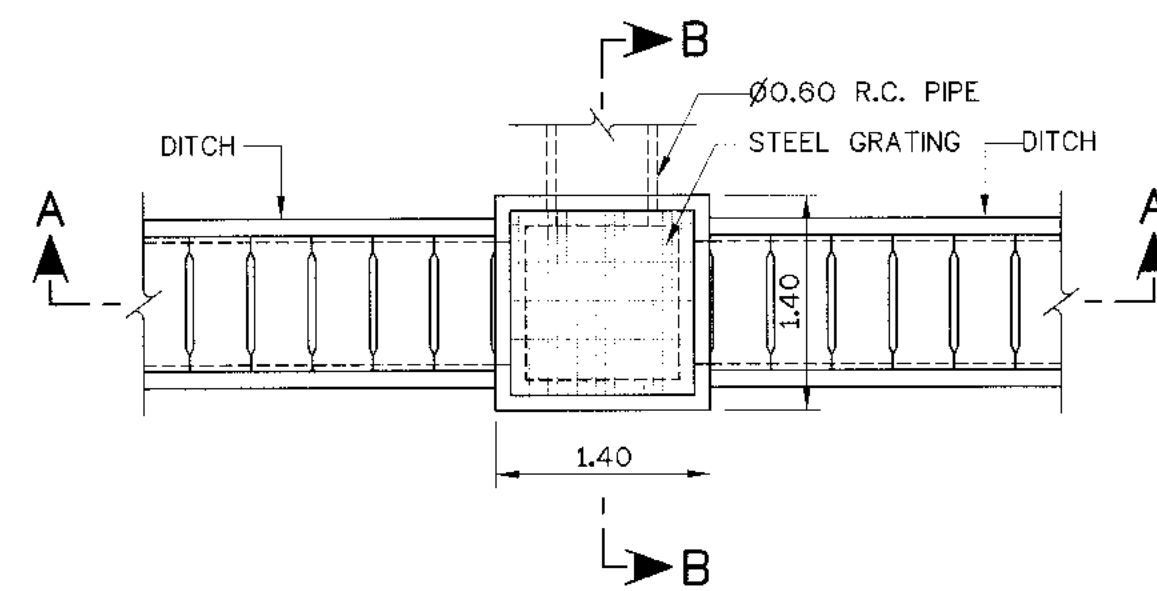


MANHOLE PLAN
NOT TO SCALE

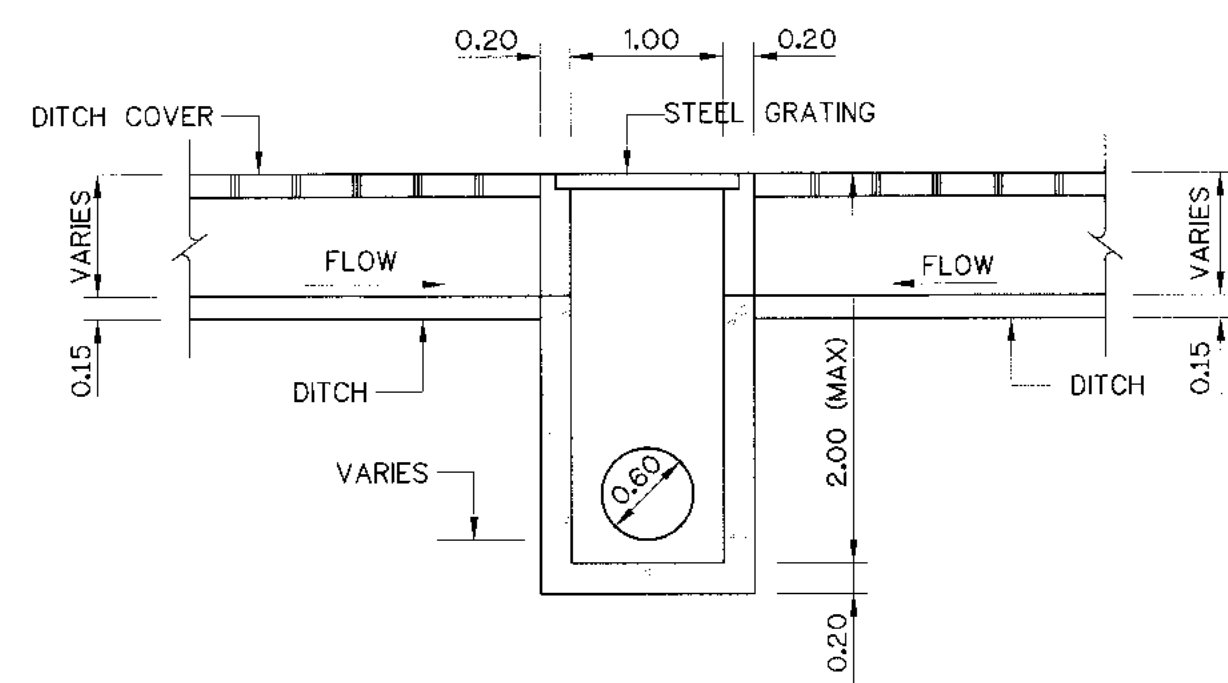


SECTION A-A
NOT TO SCALE

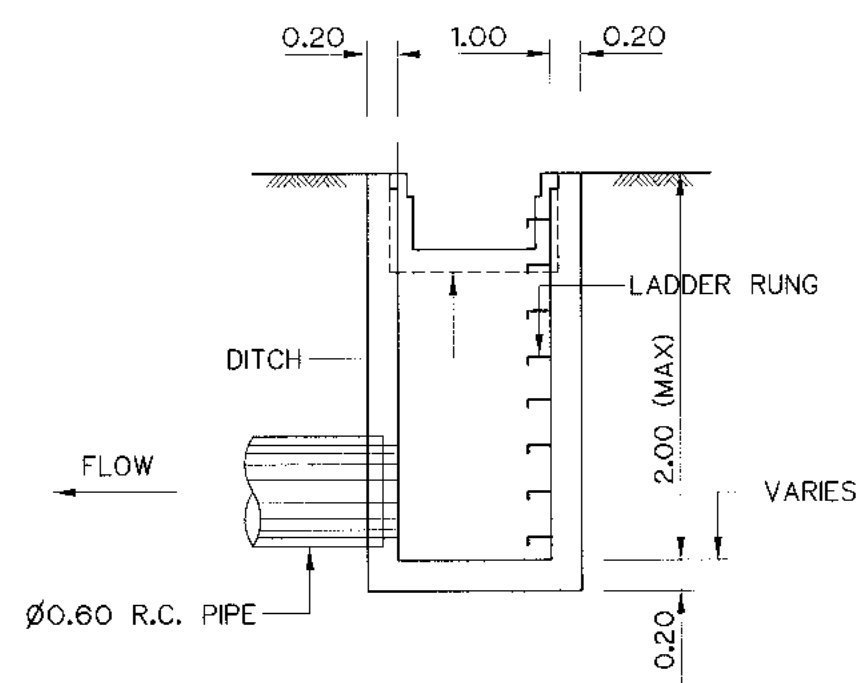


SECTION B-B
NOT TO SCALE

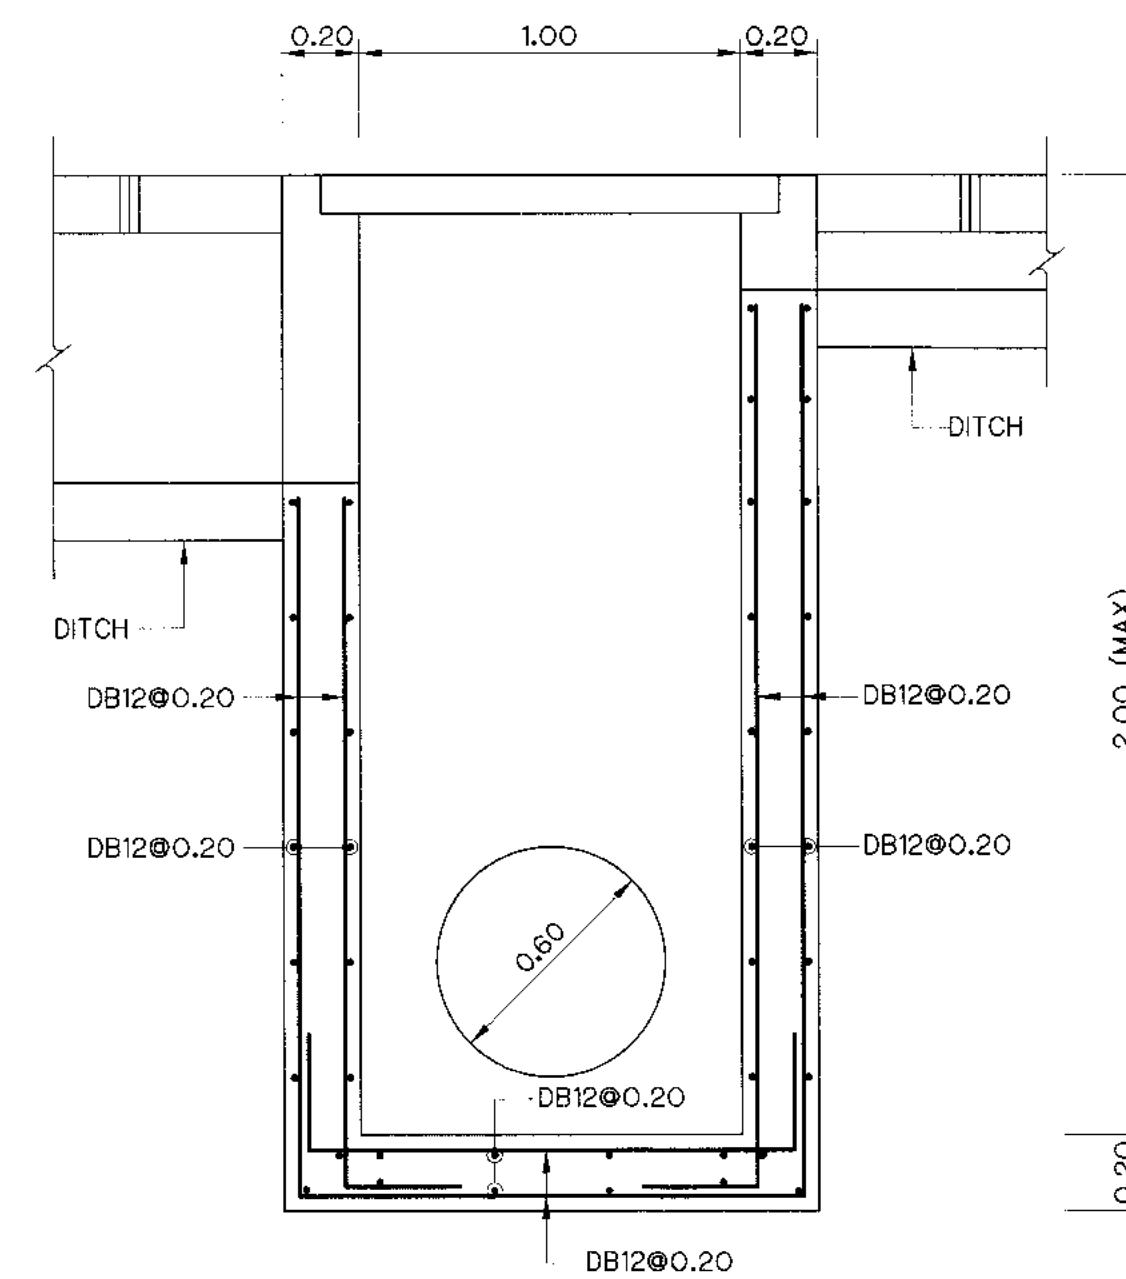


SECTION A-A (REINFORCEMENT DETAIL)
NOT TO SCALE

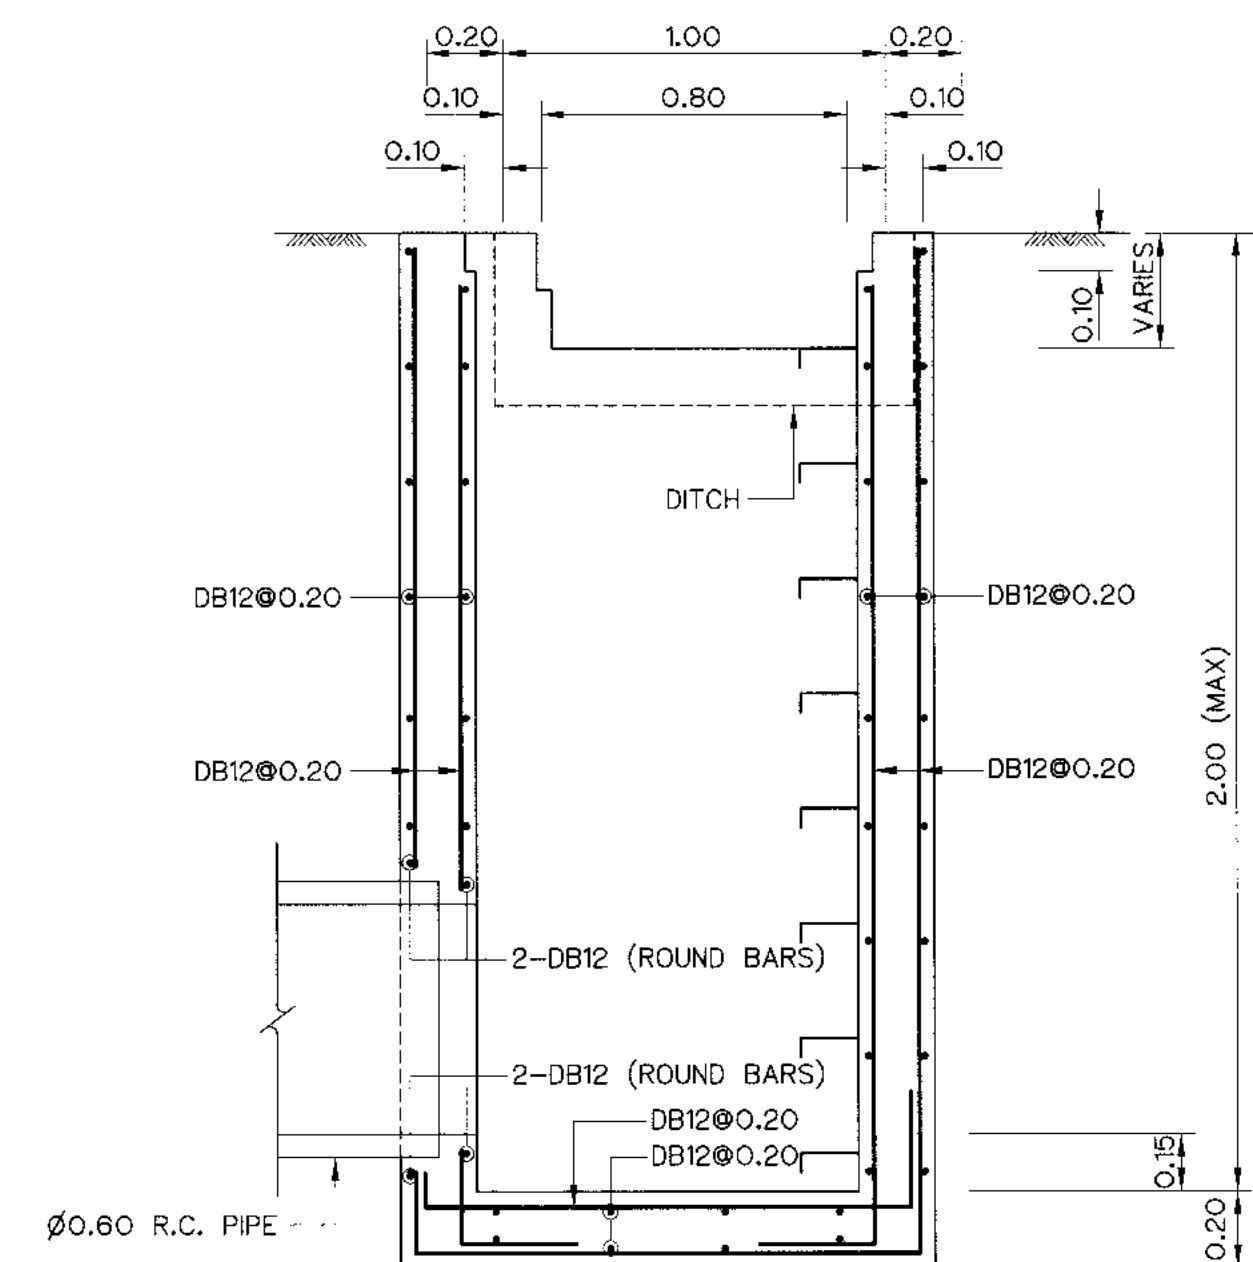


SECTION B-B (REINFORCEMENT DETAIL)
NOT TO SCALE

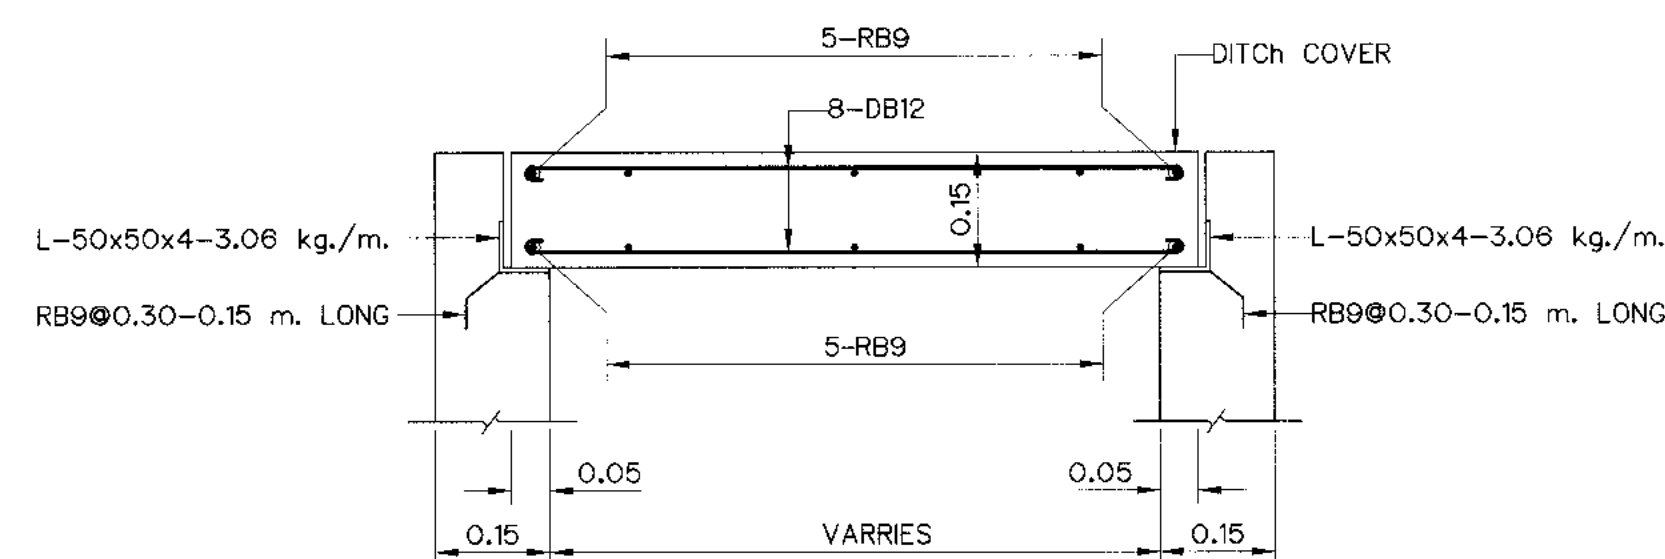

DITCH COVER DETAILS
NOT TO SCALE

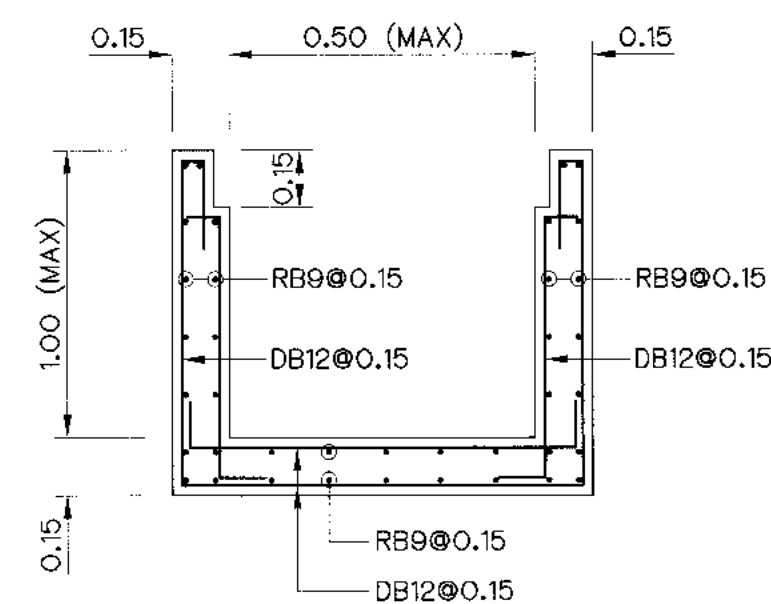

SECTION C-C
NOT TO SCALE

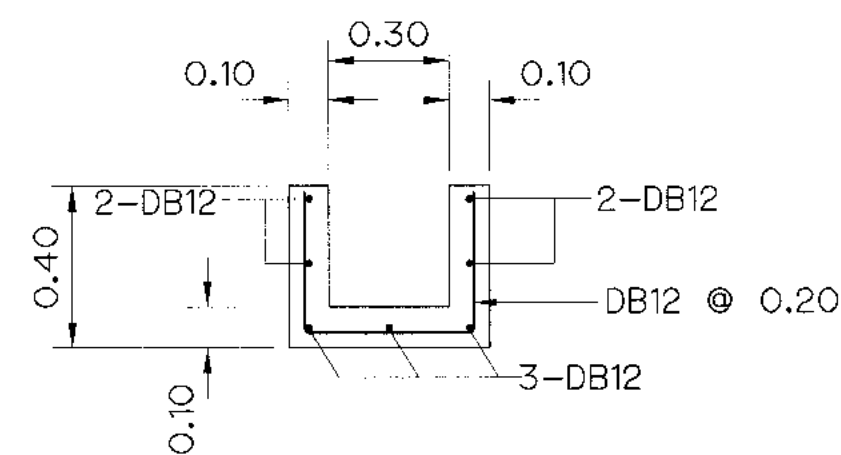


0.30 WIDTH DITCH DETAIL
NOT TO SCALE

- NOTES :**
- ALL DIMENSIONS AND ELEVATIONS (M.S.L.) ARE IN METERS, UNLESS OTHERWISE SHOWN.
 - SYMBOLS, ABBREVIATIONS AND GENERAL NOTES SEE DWG. NO. KLP-GN-03


- REFERENCE DRAWINGS :**
- POWERHOUSE, GENERAL LAY-OUT KLP-PH-01
 - TAILRACE, SECTIONS AND DETAILS KLP-TR-02

KINGDOM OF THAILAND Department of Alternative Energy Development and Efficiency MINISTRY OF ENERGY			
KLONG LAM PLOK HYDROPOWER PROJECT			
CIVIL WORKS AND TRANSMISSION LINE POWERHOUSE DITCH AND MANHOLE DETAILS			
P&C MANAGEMENT CO.,LTD.		Department of Alternative Energy Development and Efficiency MINISTRY OF ENERGY	
DESIGNED	BY 28074	REVIEWED	BY 28074
DRAWN	BY 28074	SUBMITTED	BY 28074
CHECKED	BY 28074	RECOMMENDED	BY 28074
APPROVED	BY 28074	APPROVED	BY 28074
PROJECT MANAGER		DATE	
CONSULTANTS		DEDE	
DRAWING NO.		SHEET NO.	
KLP-PH-18		90 OF 110	

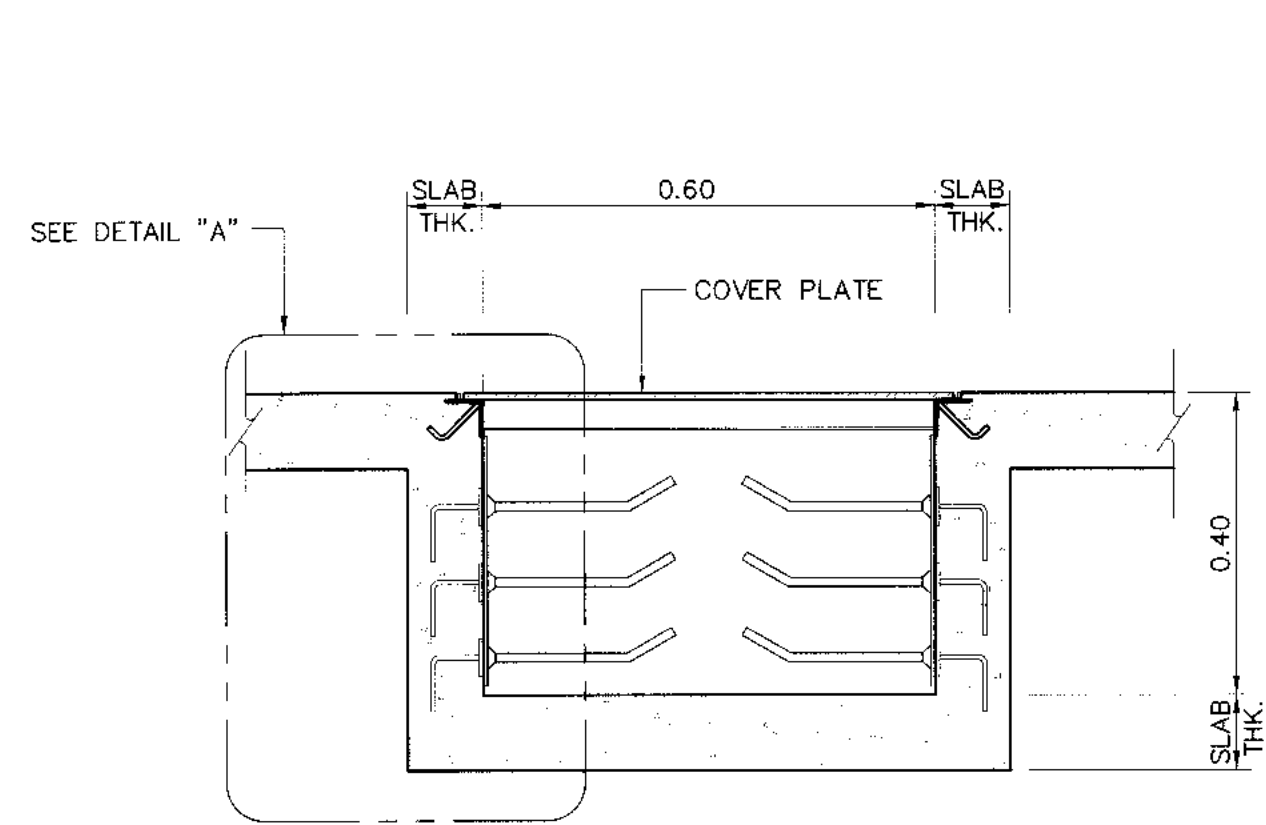


IN DOOR CABLE TRENCH

SCALE 1:10

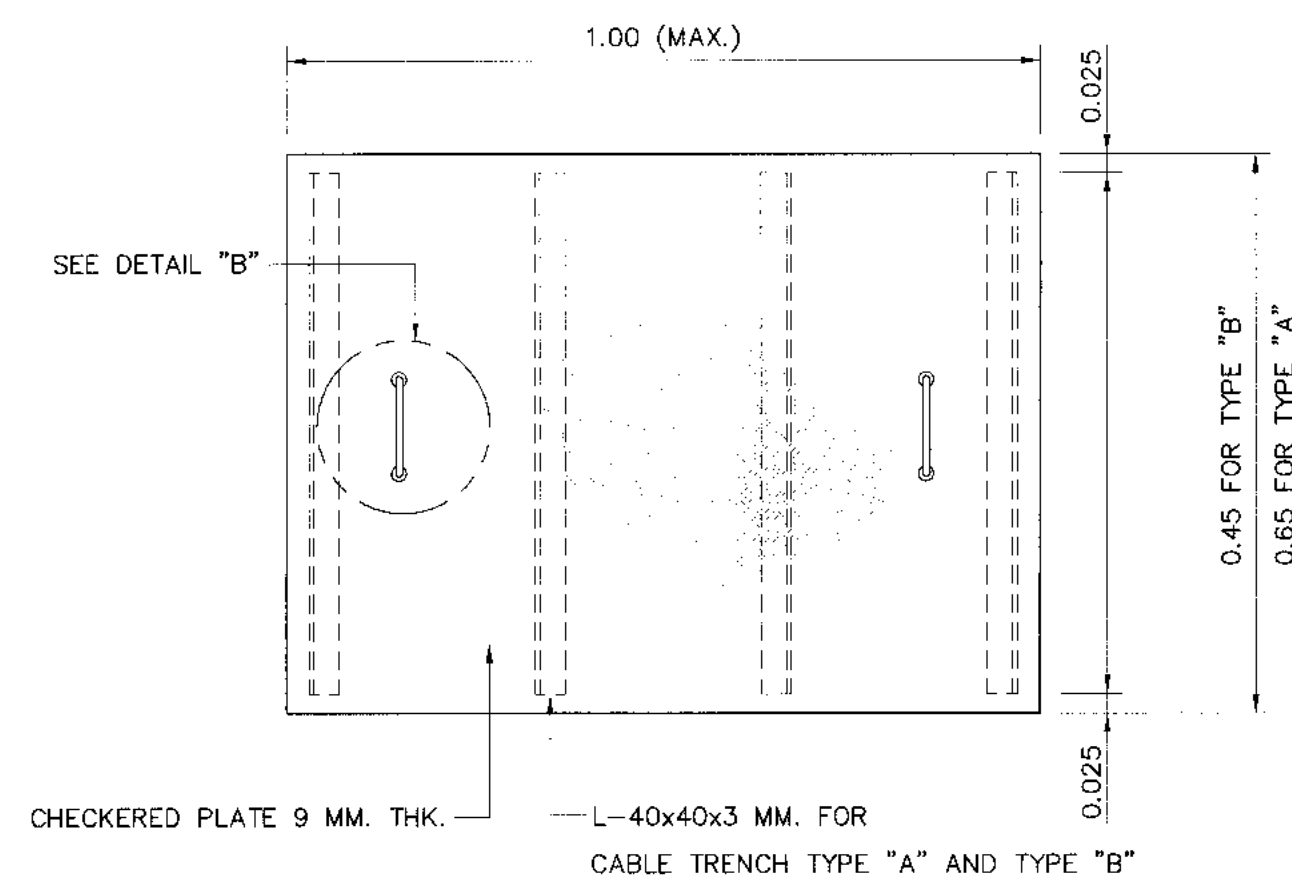


COVER PLATE FOR IN DOOR

SCALE 1:10

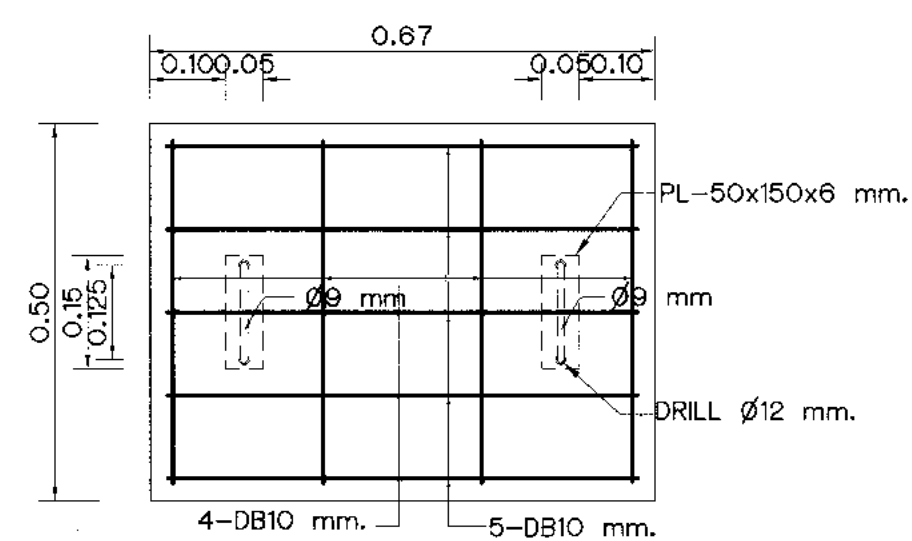


OUT DOOR COVER CABLE TRENCH

SCALE 1:5

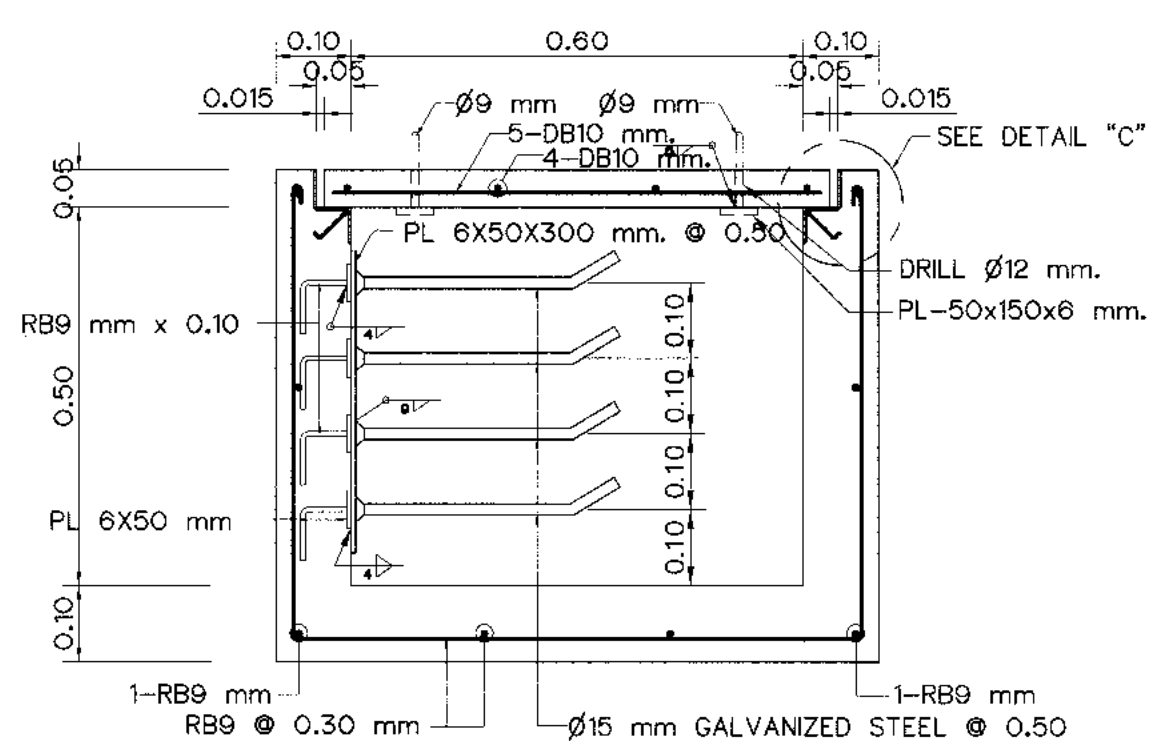


OUT DOOR CABLE TRENCH

SCALE 1:10

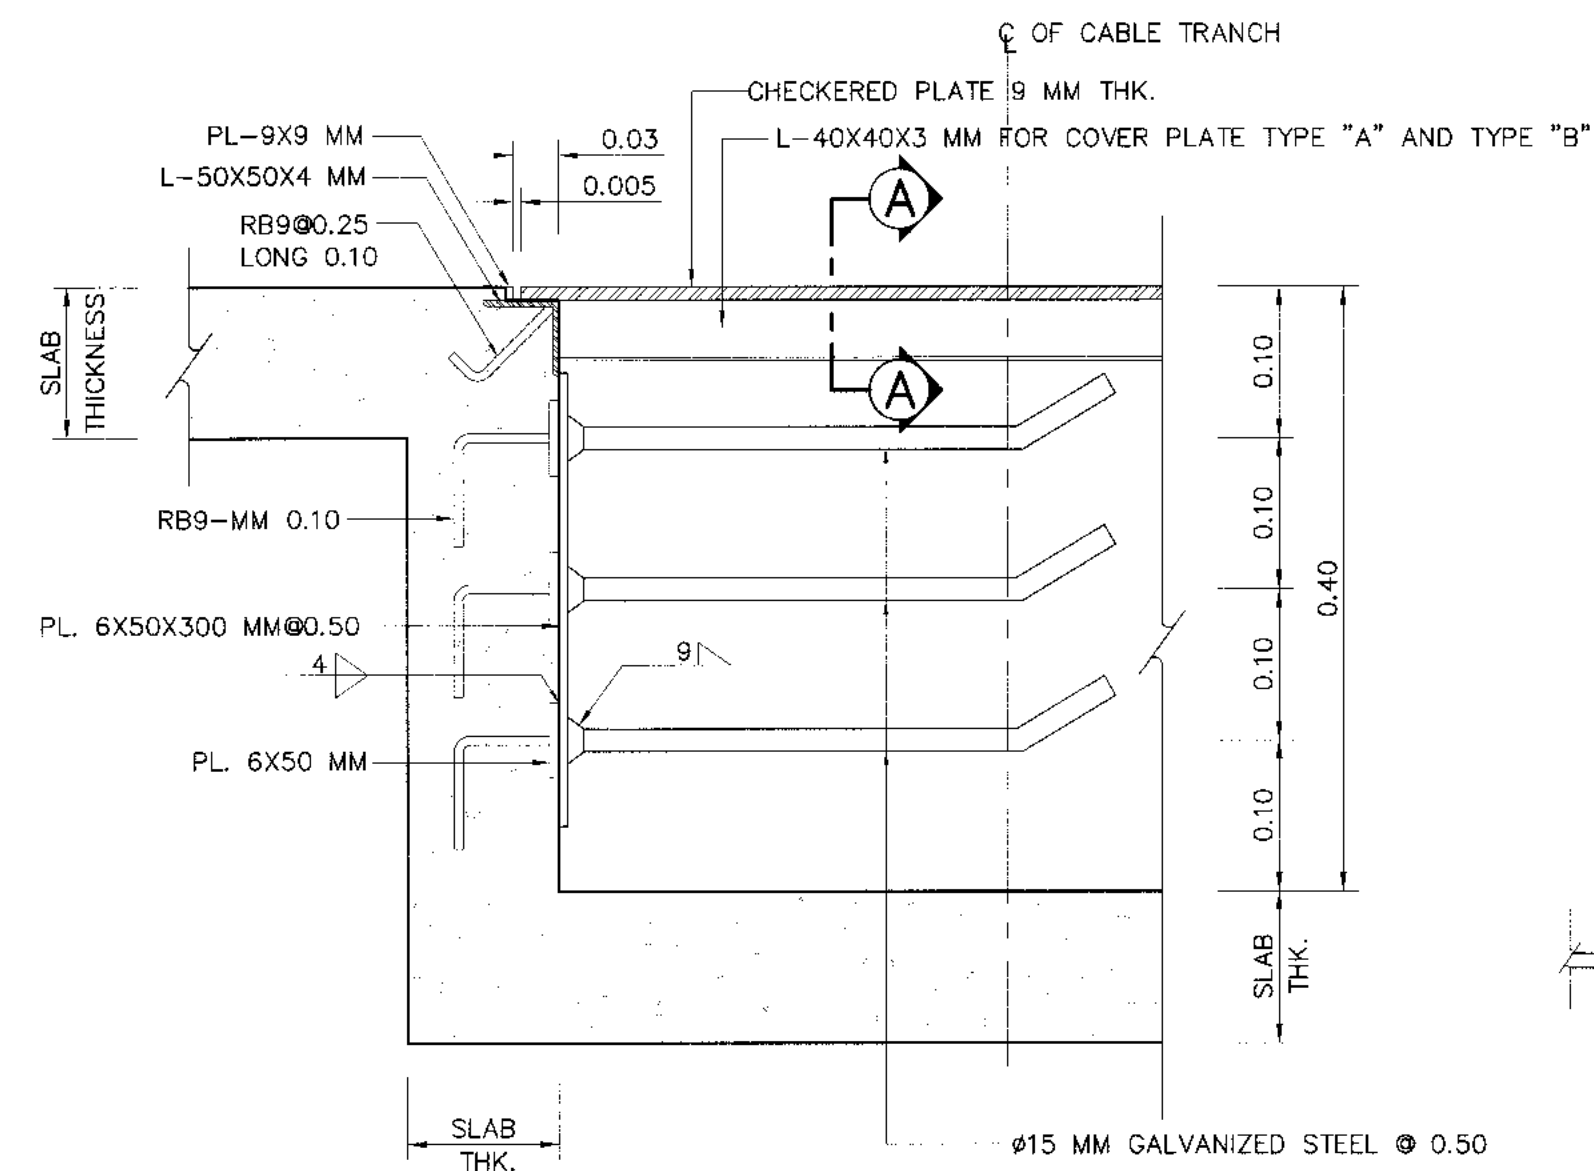


DETAIL "A"

SCALE 1:5

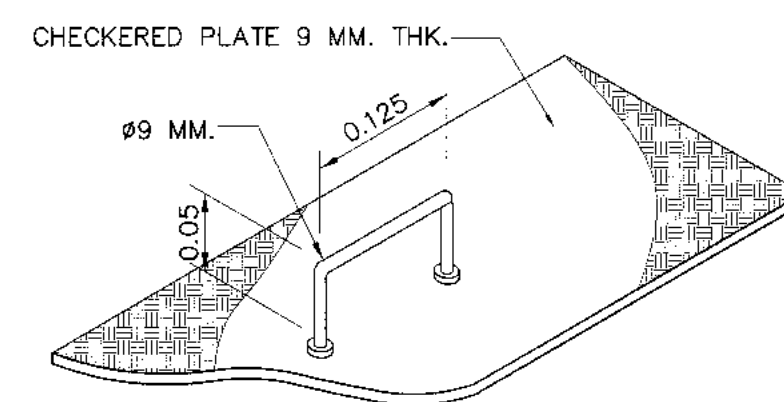

DETAIL "B"

NOT TO SCALE

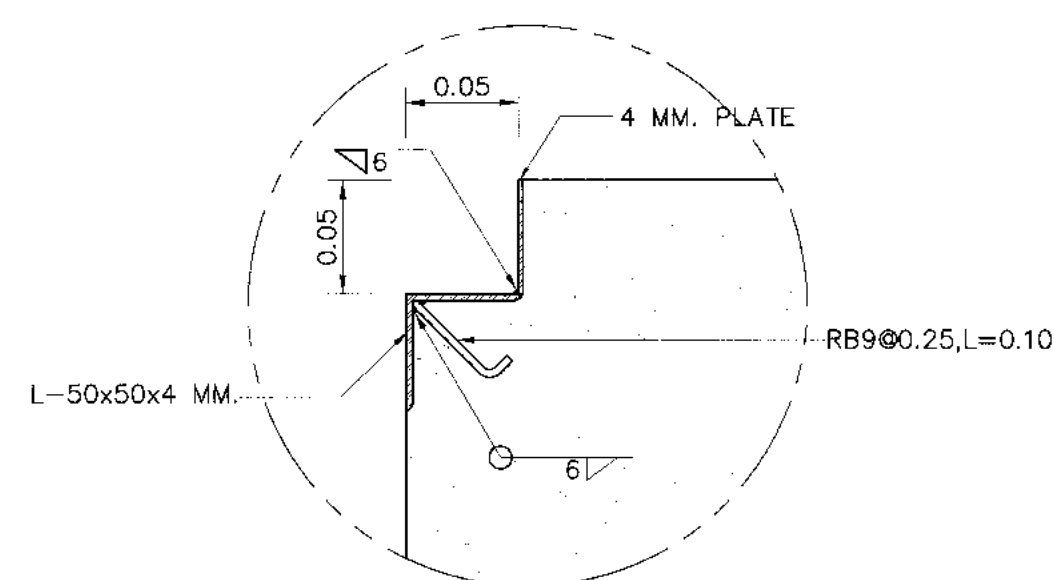

DETAIL "C"


NOT TO SCALE

NOTES :

- ALL DIMENSIONS AND ELEVATIONS ARE IN METERS, REINFORCEMENT BARS ARE IN MILLIMETERS, UNLESS OTHERWISE SHOWN.
- SYMBOLS, ABBREVIATIONS AND GENERAL NOTES SEE DWG. NO. KLP-GN-03.
- STEEL COVER FOR IN DOOR TRENCH SHALL BE COATED WITH NON BLEEDING TYPE COAL TAR EPOXY.


REFERENCE DRAWINGS :

- POWERHOUSE, GENERAL LAY-OUT KLP-PH-01
- POWERHOUSE, PLAN 1st FLOOR KLP-PH-02

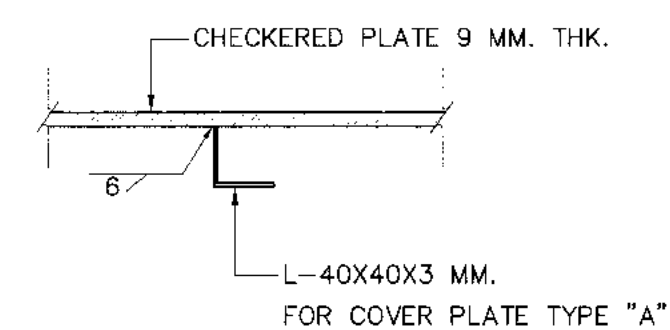


SECTION A-A

NOT TO SCALE

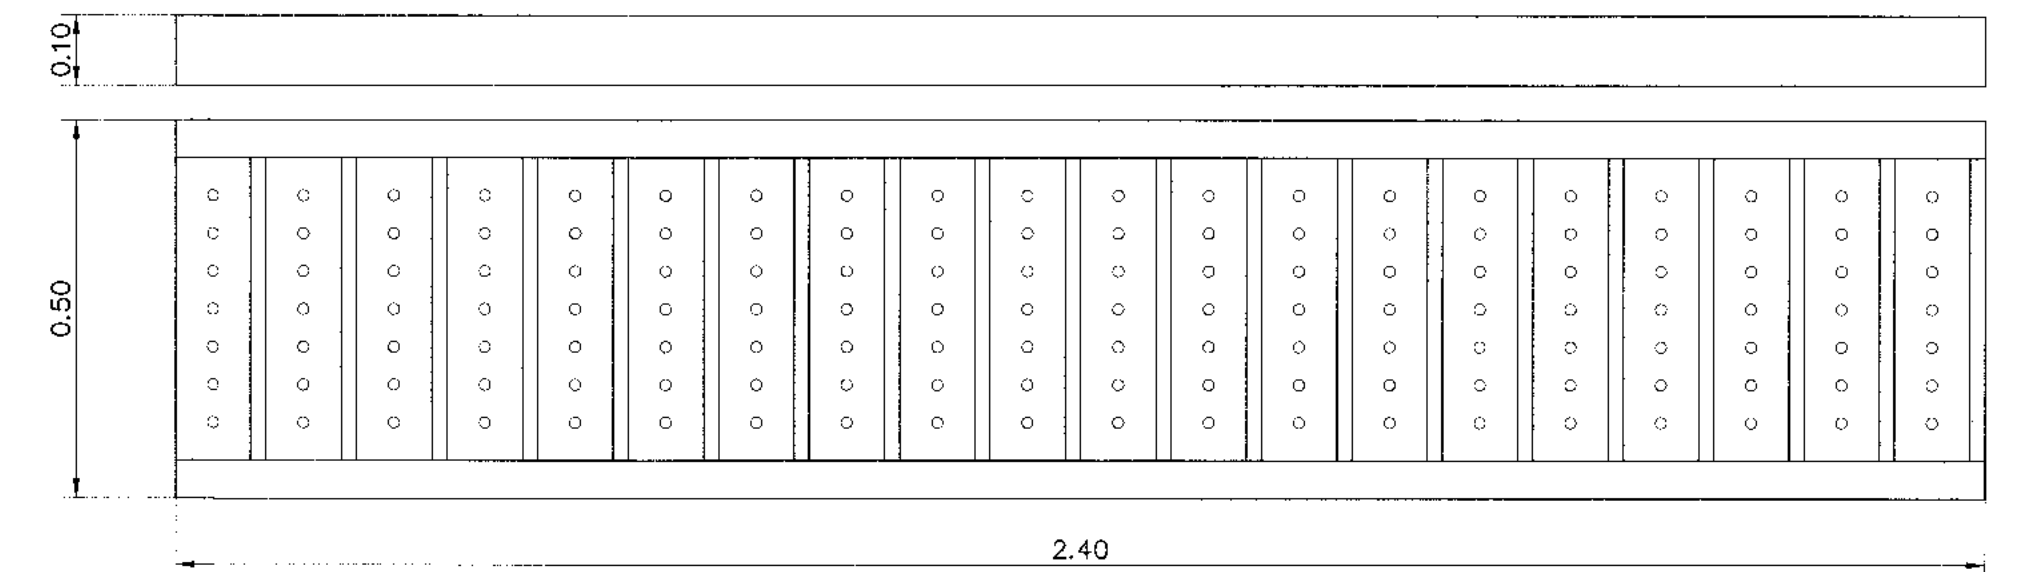

STRAIGHT LENGTH

NOT TO SCALE

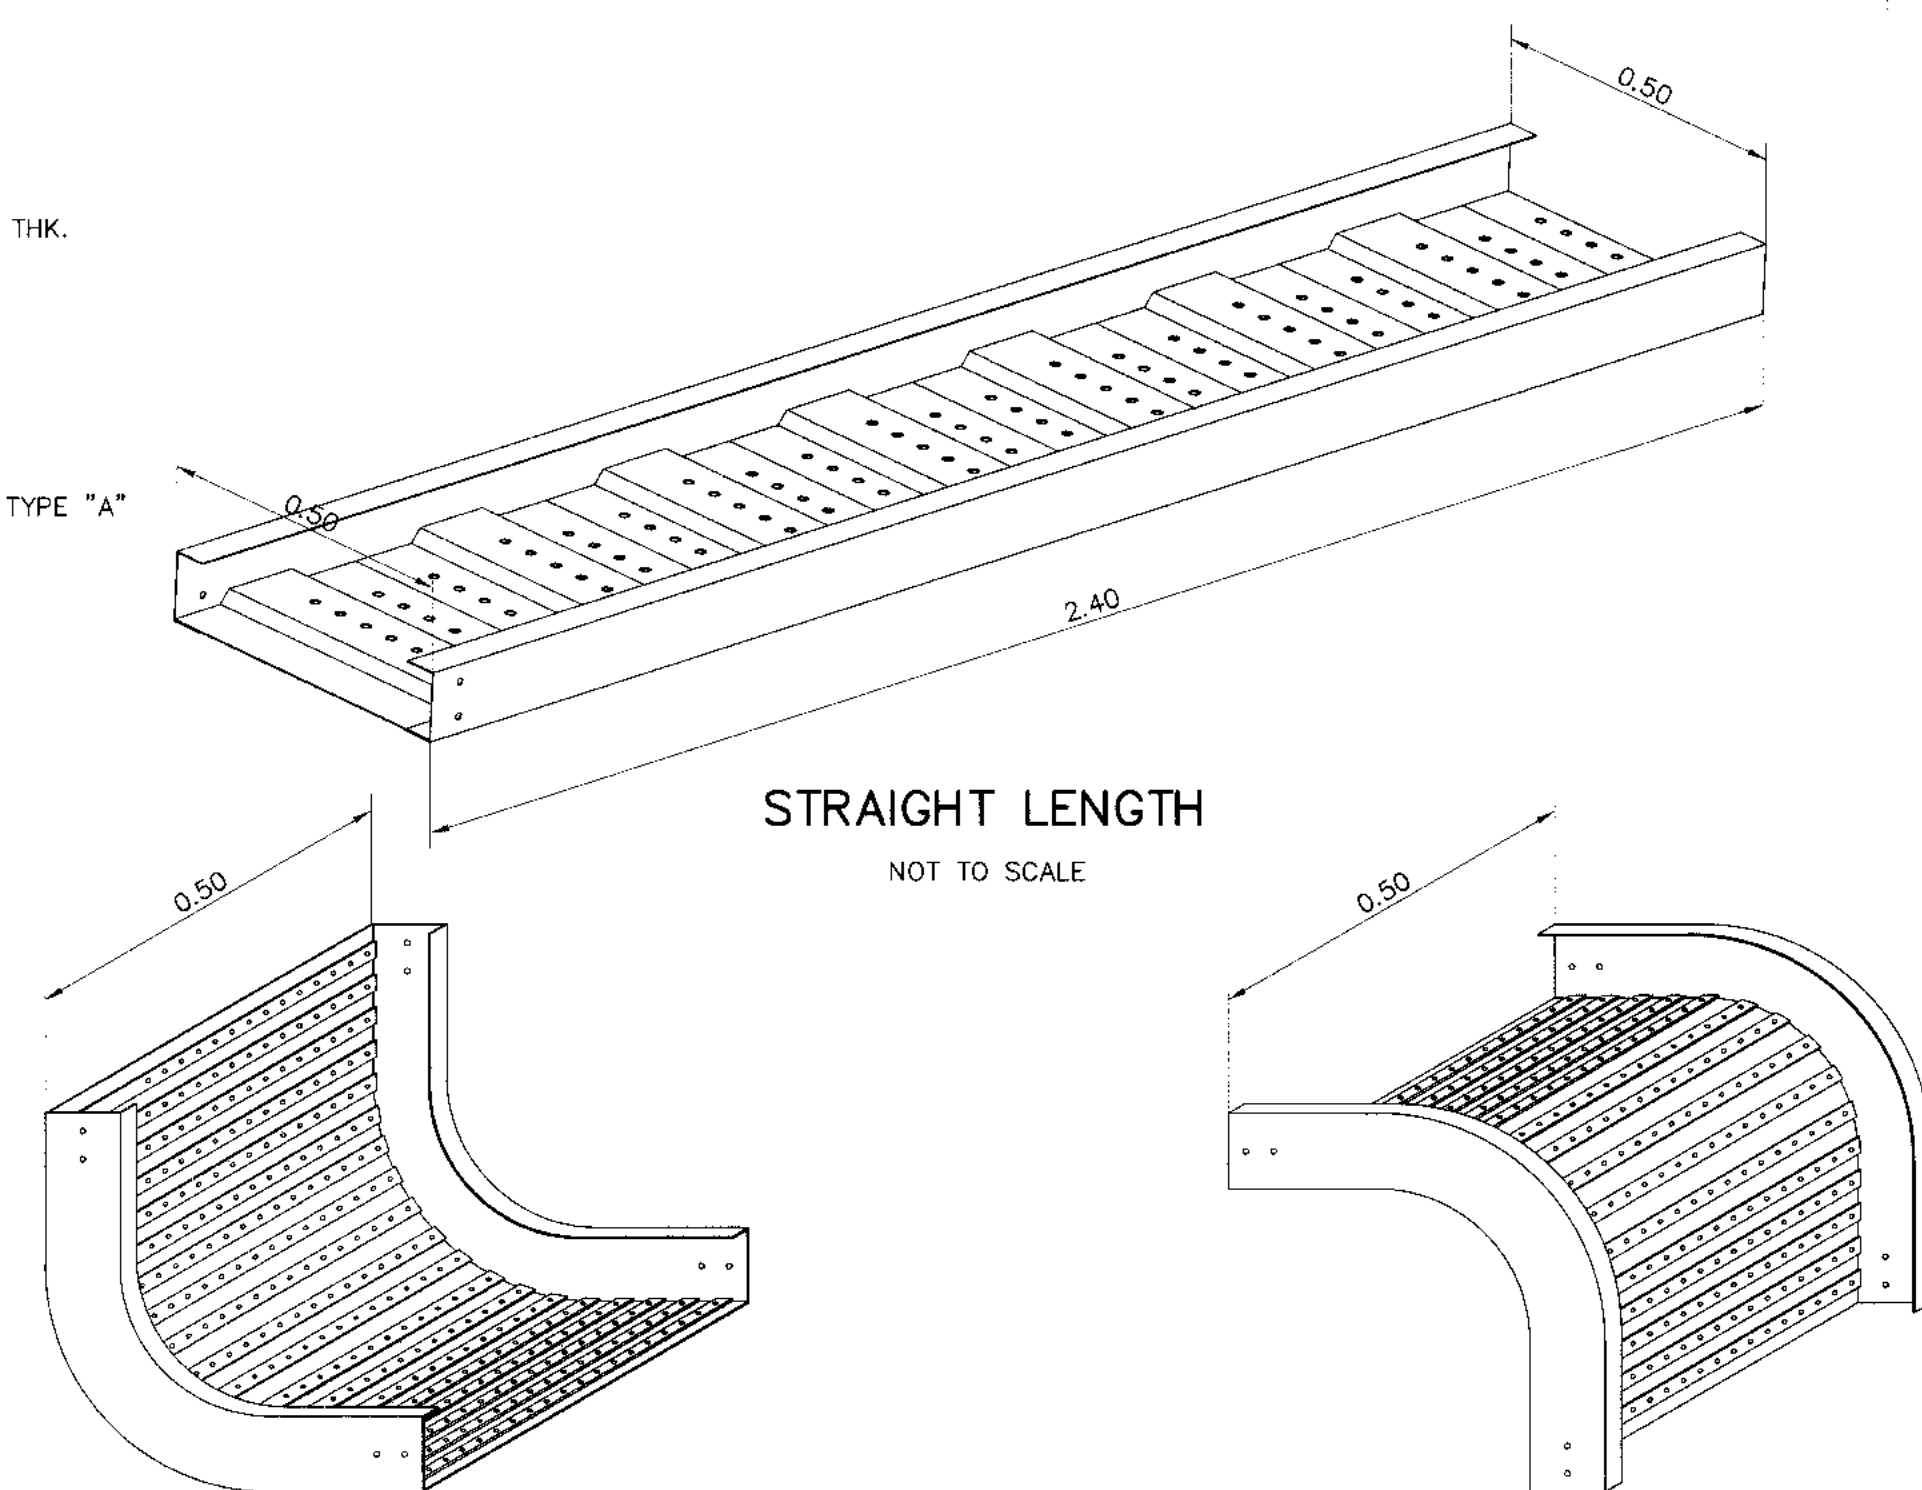


OUTSIDE VERTICAL RISERS

NOT TO SCALE

INSIDE VERTICAL RISERS

NOT TO SCALE

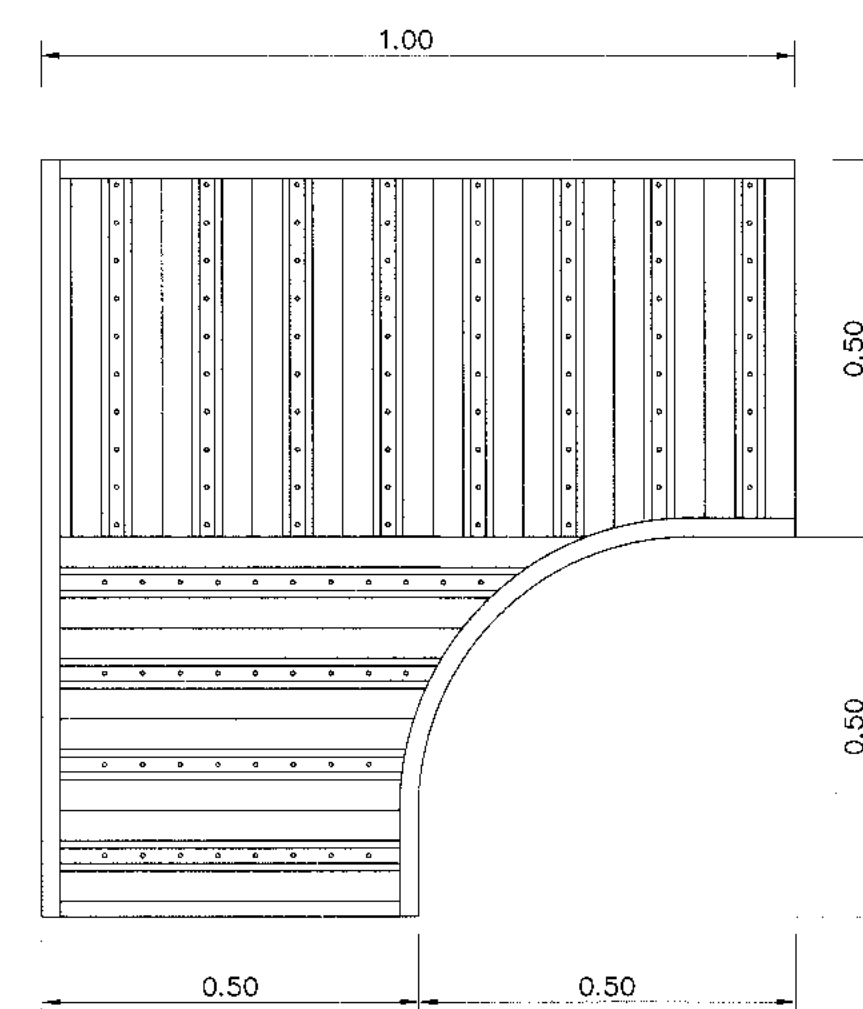

HORIZONTAL 90 ELBOWS




NOT TO SCALE

CABLE TRAY DETAIL

NOT TO SCALE

MATERIALS : SHEET STEEL 1.5MM.
SURFACE FINISH : POWDER
COATED IN TEXTURED RAL
7032 OR HOT-DIP GALVANIZED
(UPON YOU REQUIREMENTS)
ASSEMBLY : WELDING METHOD
APPLICATION : USING FOR INDOOR & OUTDOOR INSTALLATION WORK

KINGDOM OF THAILAND Department of Alternative Energy Development and Efficiency MINISTRY OF ENERGY	
KLONG LAM PLOK HYDROPOWER PROJECT	
CIVIL WORKS AND TRANSMISSION LINE POWERHOUSE CABLE TRENCH DETAILS	
DESIGNED 08/03/2559 08/03/2559	REVIEWED 08/03/2559 08/03/2559
DRAWN 08/03/2559 08/03/2559	SUBMITTED 08/03/2559 08/03/2559
CHECKED 08/03/2559 08/03/2559	APPROVED 08/03/2559 08/03/2559
PROJECT MANAGER DATE	DRAWING NO. KLP-PH-19
CONSULTANTS DEDE	SHEET NO. 91 OF 110

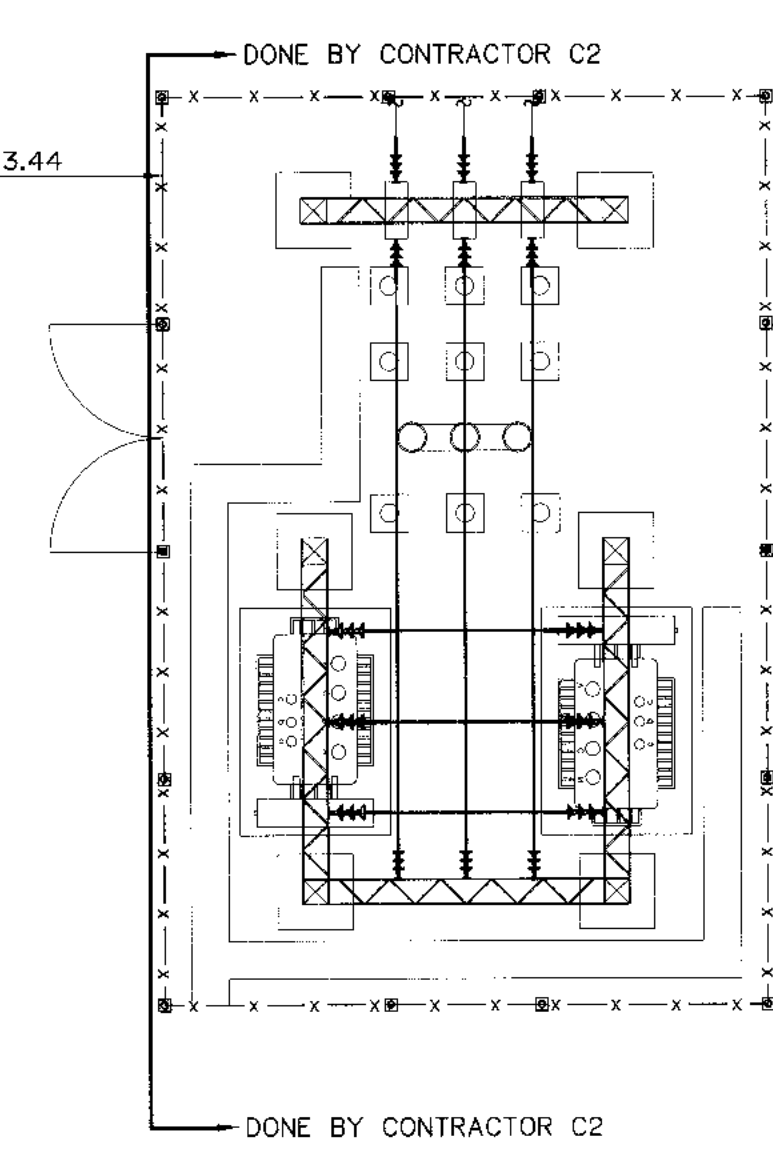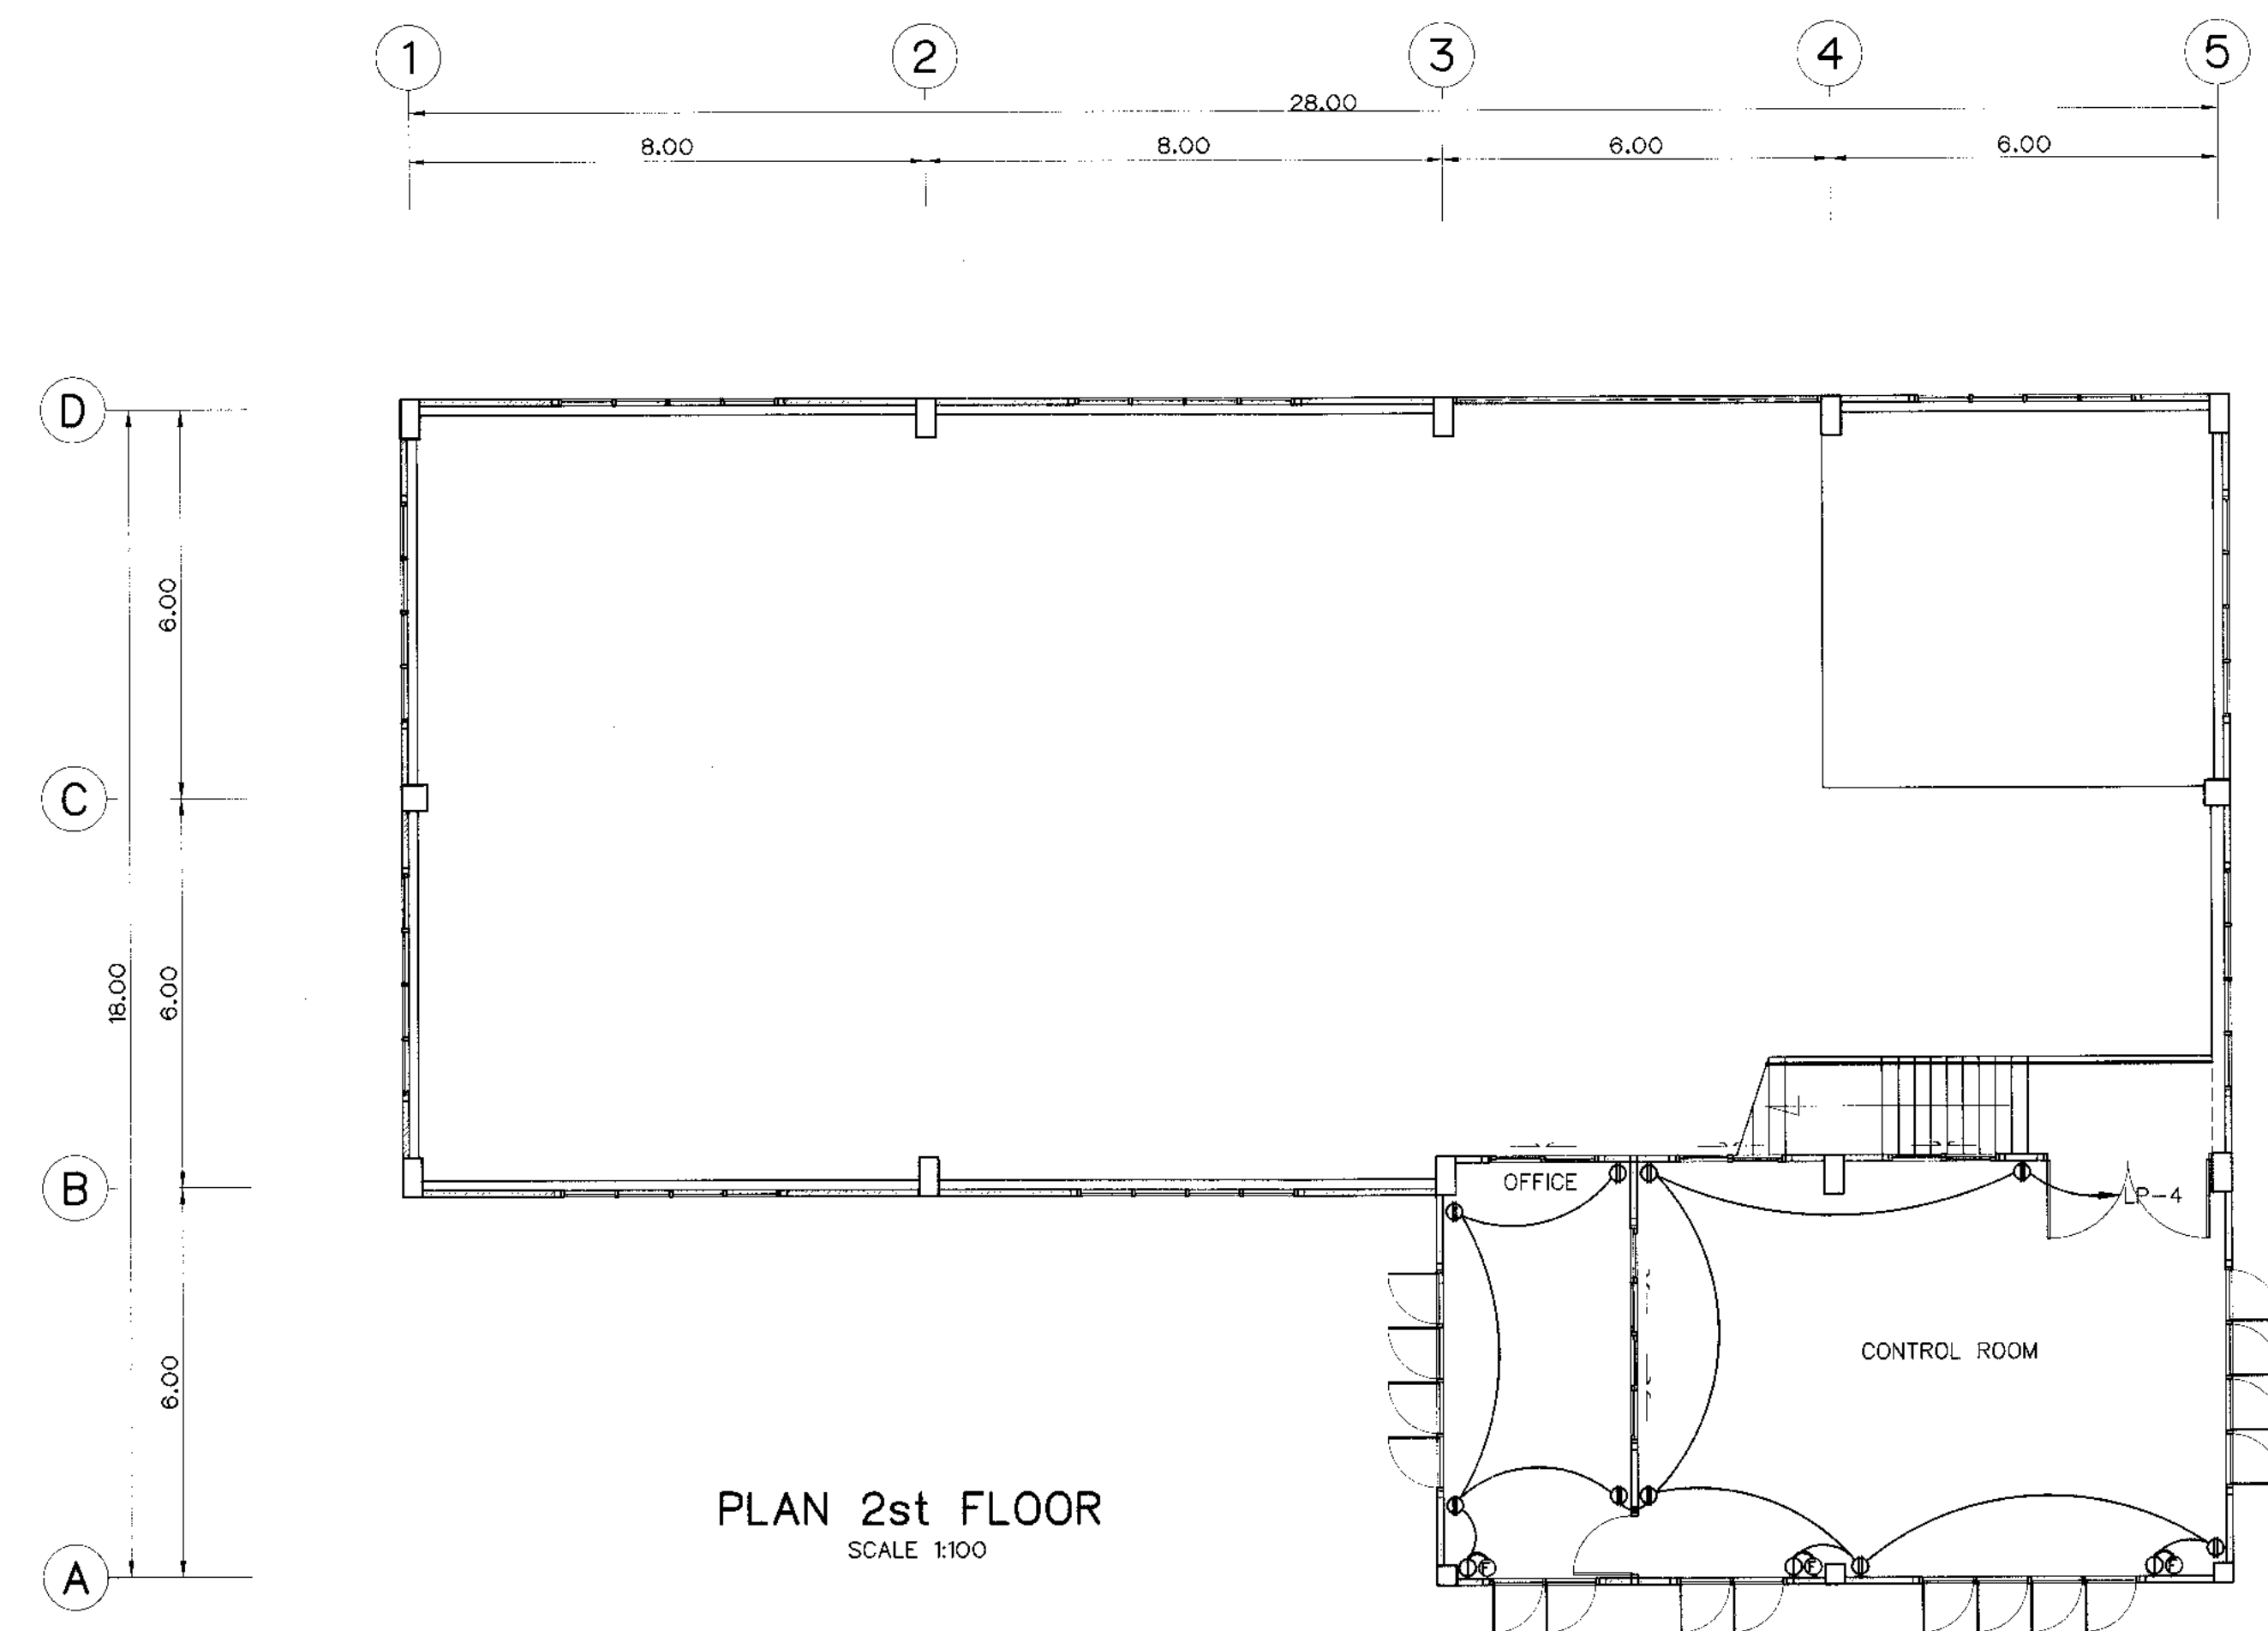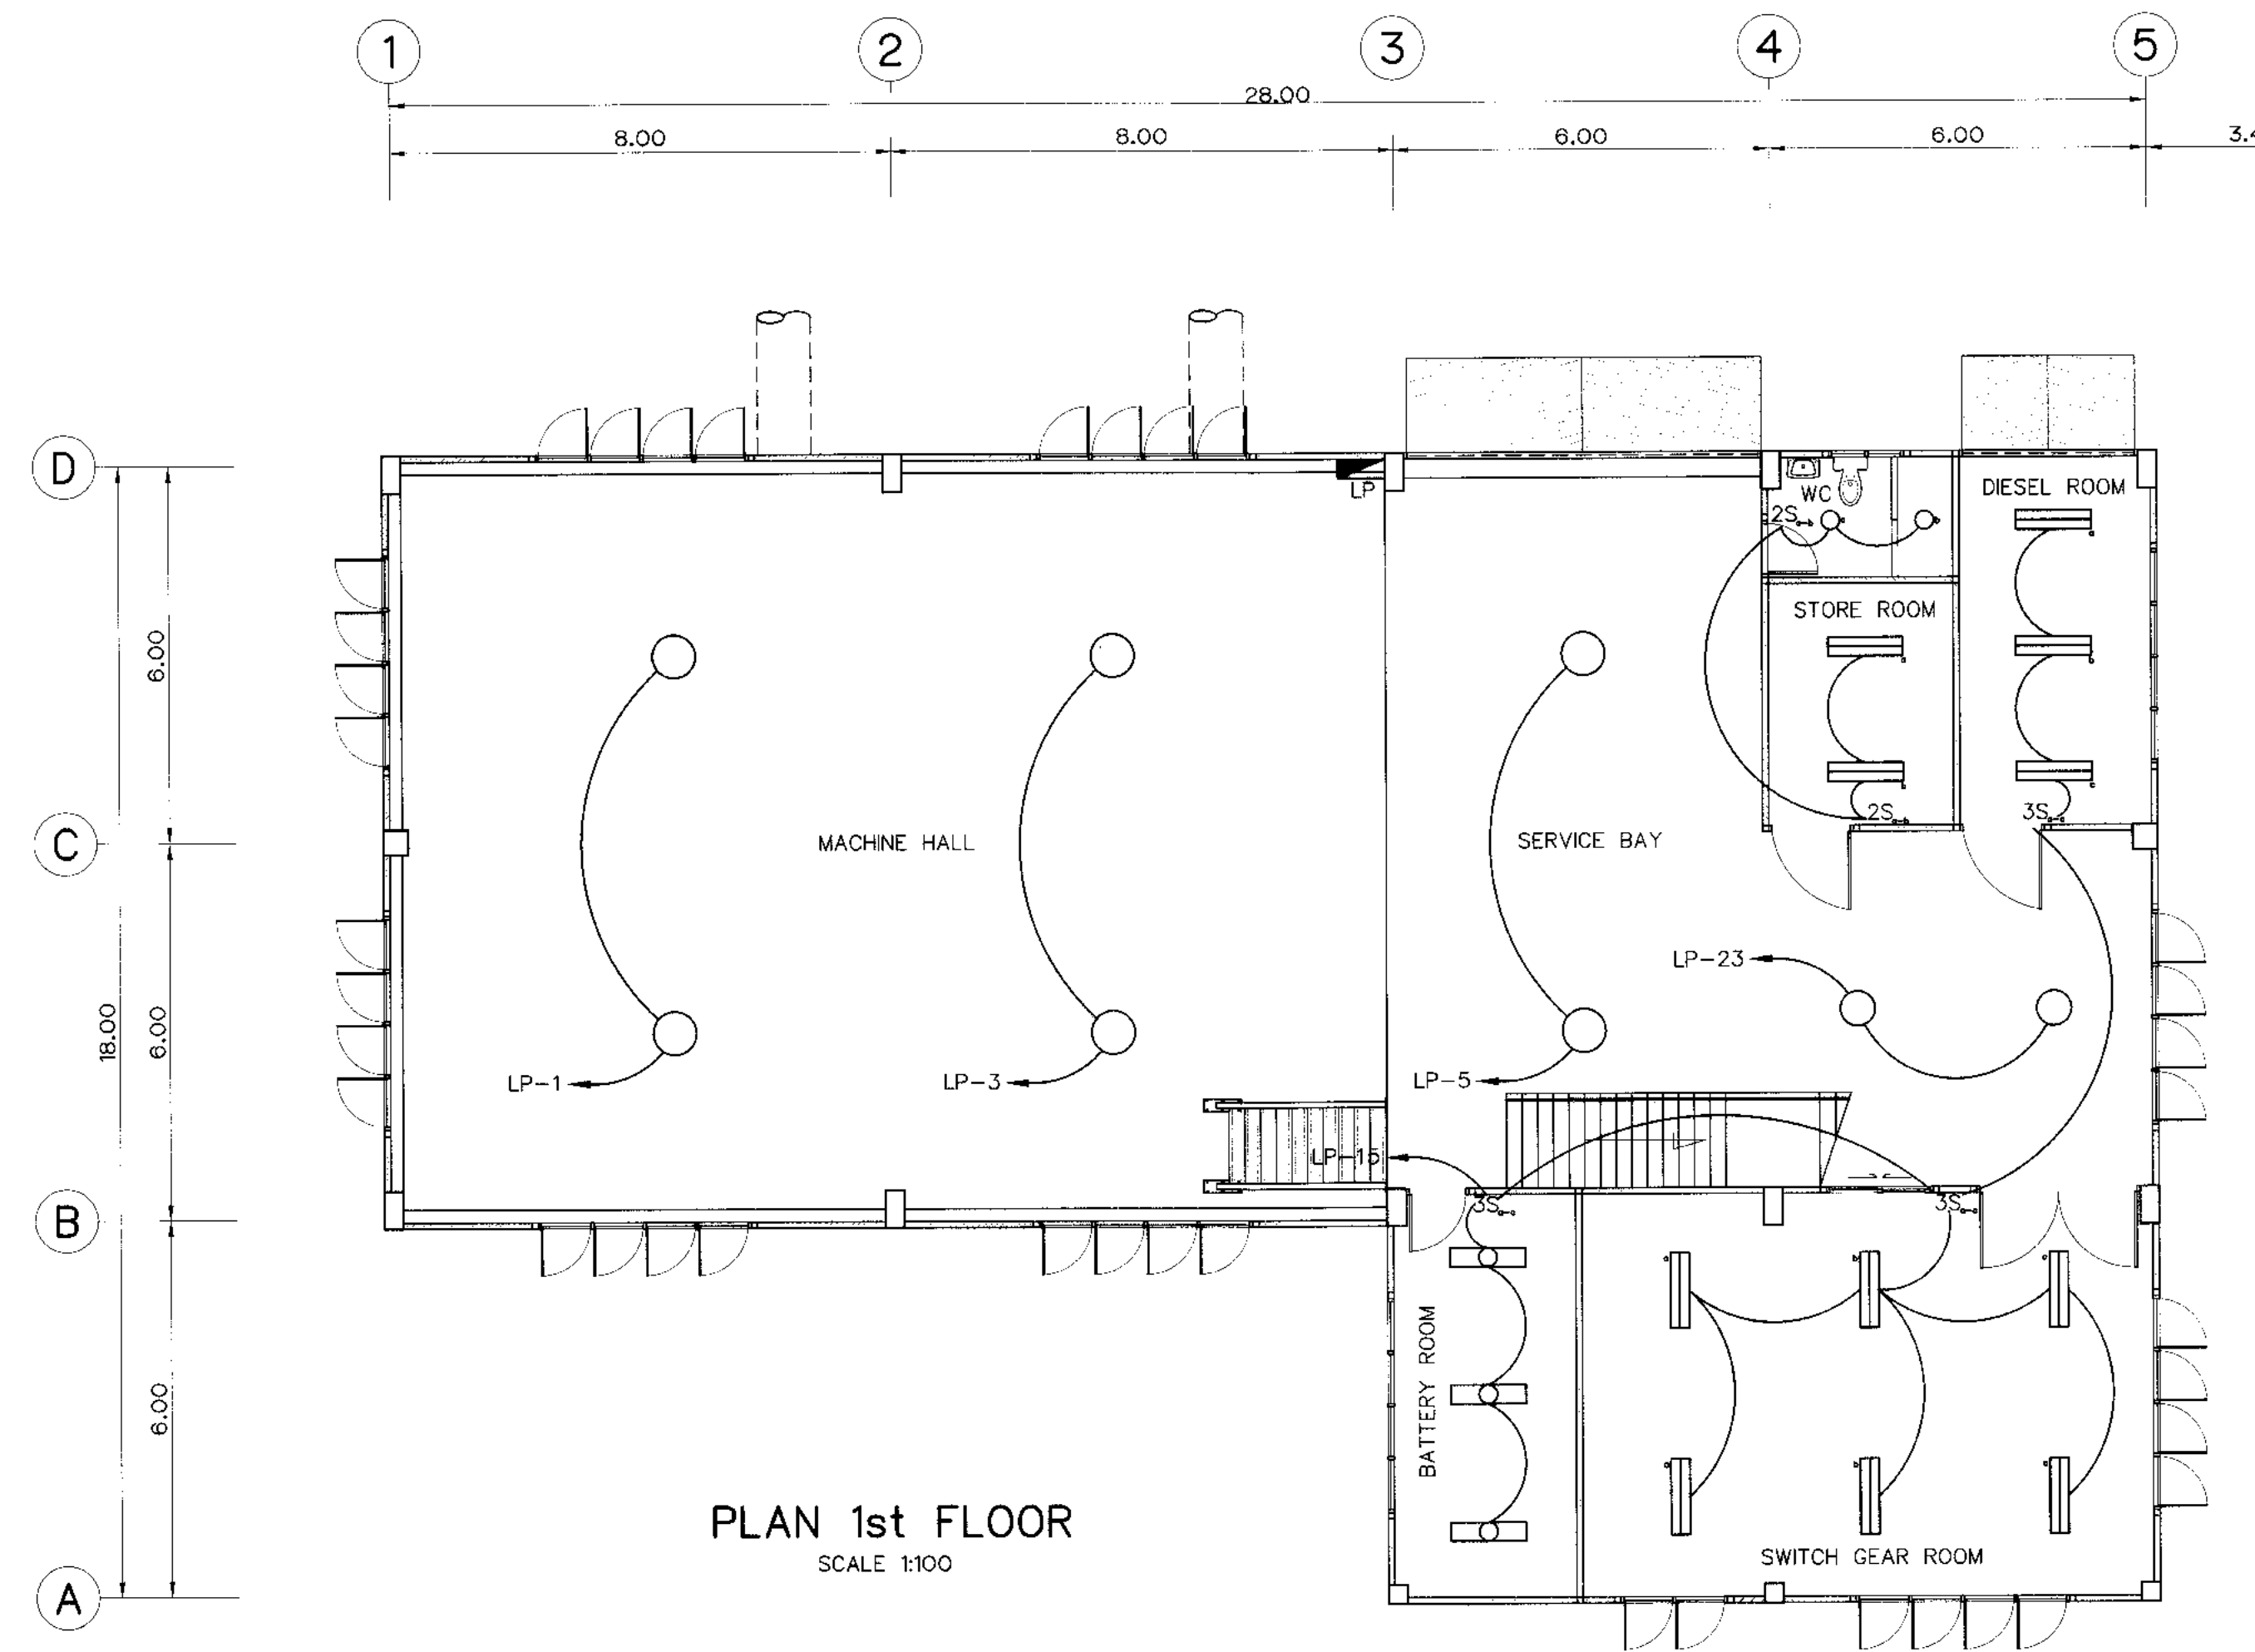


LEGENDS :

- 2x36 W. FLUORESCENT LAMP (HANGING OR CEILING TYPE) WITH BALLAST LOW LOSS, CAPACITOR AND STARTOR AT SWITCH "a"
- 2x36 W. FLUORESCENT LAMP (CORROSION PROOF) WITH BALLAST LOW LOSS, CAPACITOR AND STARTOR
- 1x36 W. FLUORESCENT LAMP (HANGING CEILING TYPE) WITH BALLAST LOW LOSS, CAPACITOR AND STARTOR, AT SWITCH "a"
- 1x20 W. COMPACT FLUORESCENT (WALL TYPE, OUTDOOR IP54)
- SWITCH "3" SETS FOR SWITCH "a" TO "c"
- TWO-WAYS SWITCH
- SIMPLEX RECEPTACLE WITH GROUND, 10 A. 220 VAC.
- 20 W. COMPACT FLUORESCENT
- EXHAUST FAN 12"
- OUTDOOR BOLLARD TYPE WITH 20 W. COMPACT FLUORESCENT
- DUPLEX RECEPTACLE WITH GROUND, 10 A. 220 VAC.
- POWER RECEPTACLE 3P+N+E 32 A. 400 VAC.
- HIGH BAY FIXTURE 1x400 W. HIGH PRESSURE SODIUM
- HIGH BAY FIXTURE 1x250 W. HIGH PRESSURE SODIUM
- EMERGENCY LIGHTING 2x55 W. HALOGEN W/SEALED LEAD ACID BATTERY BACKUP 2 HOURS
- AIR CONDITIONING, SPLIT TYPE
- LOAD PANEL 3 PHASE (18 CIRCUITS) WITH MAIN CIRCUIT BREAKER
- LIGHTING CONTROL PANEL
- SECONDARY LINES, 380/220 V 50 MM THW OVERHEAD INSULATED CABLES, 3Ø 4 WIRE
- UNDERGROUND WIRING IN CONDUIT

3				
2				
1				
NO.	DATE	REVISIONS	CHECKED	APPROVED

KINGDOM OF THAILAND Department of Alternative Energy Development and Efficiency MINISTRY OF ENERGY			
KLONG LAM PLOK HYDROPOWER PROJECT			
CIVIL WORKS AND TRANSMISSION LINE POWERHOUSE ELECTRIC AND LIGHTING SYSTEMS (SHEET 1/4)			
P&C MANAGEMENT CO.,LTD.	REVIEWED <i>[Signature]</i>	DEPARTMENT OF ALTERNATIVE ENERGY DEVELOPMENT AND EFFICIENCY MINISTRY OF ENERGY	
DESIGNED <i>[Signature]</i> 25/01/604	SUBMITTED <i>[Signature]</i>		
DRAWN <i>[Signature]</i>	RECOMMENDED <i>[Signature]</i>		
CHECKED <i>[Signature]</i> 25/01/604	APPROVED <i>[Signature]</i>		
PROJECT MANAGER <i>[Signature]</i>	08/03/2559 DATE	DRAWING NO. KLP-PH-20	SHEET NO. 92 OF 110

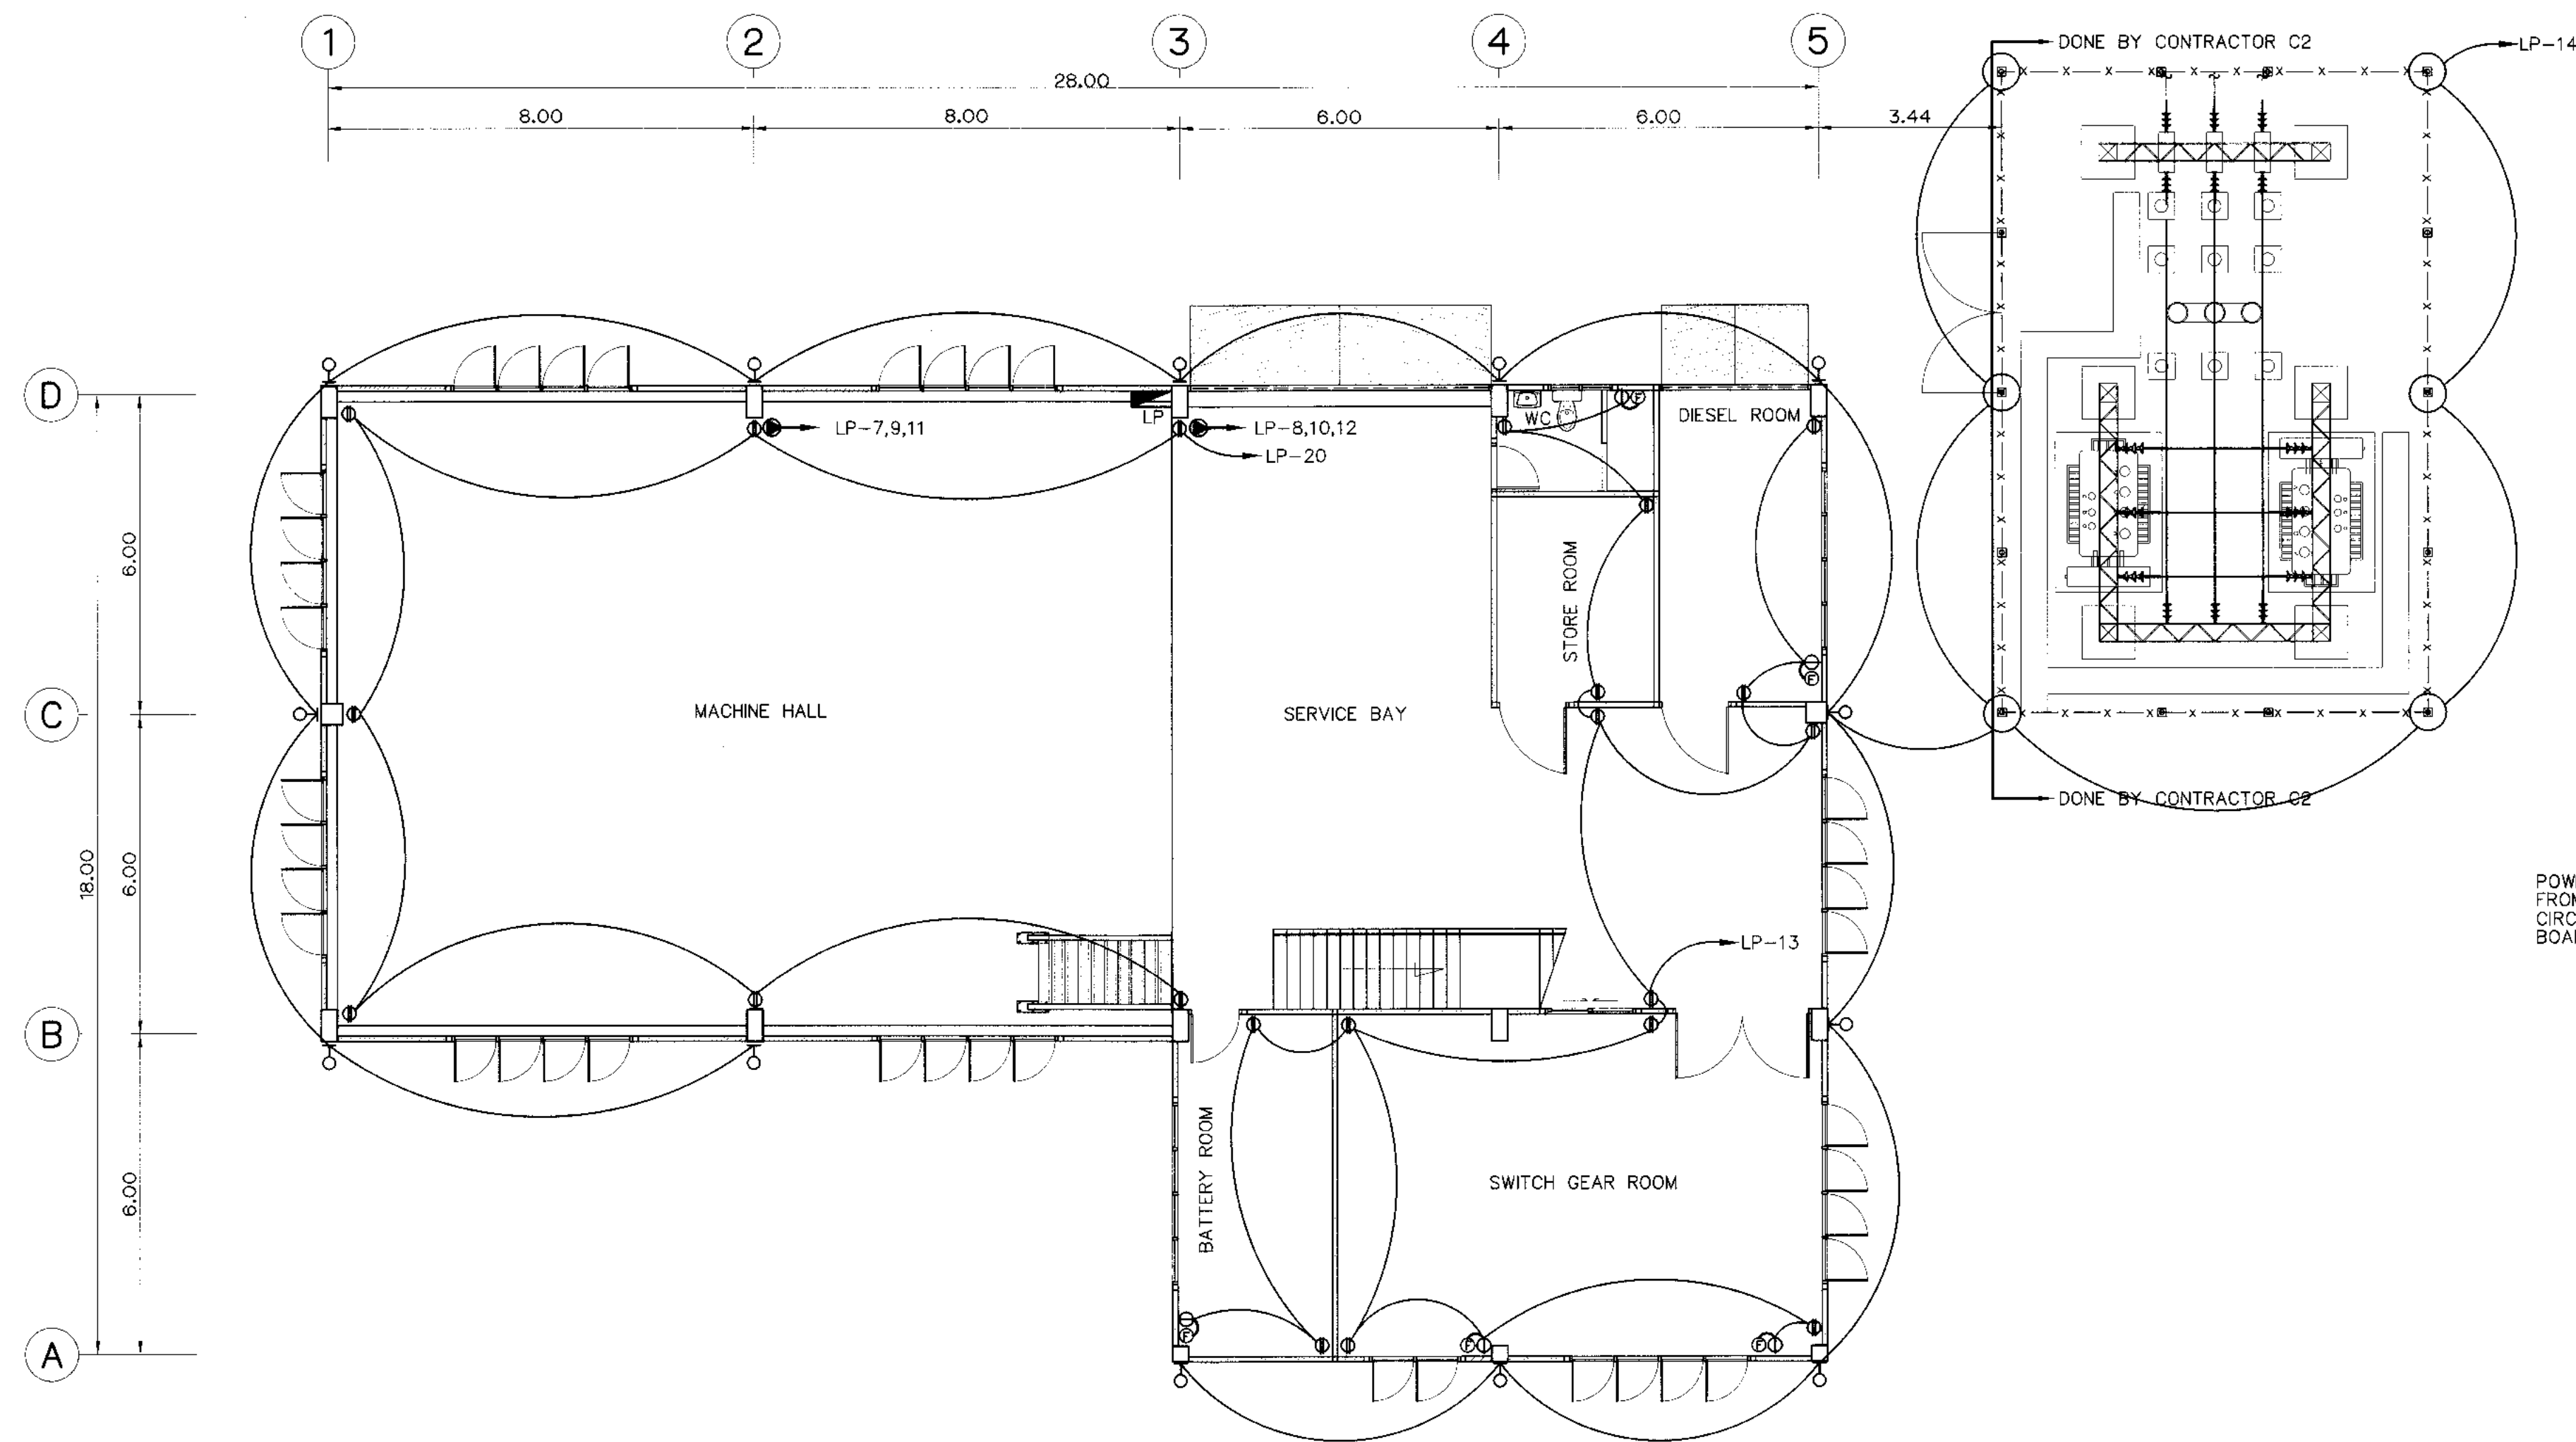


PLAN 1st FLOOR
SCALE 1:100



LEGENDS :

- 2x36 W. FLUORESCENT LAMP (HANGING OR CEILING TYPE) WITH BALLAST LOW LOSS, CAPACITOR AND STARTOR AT SWITCH "a"
- 2x36 W. FLUORESCENT LAMP (CORROSION PROOF) WITH BALLAST LOW LOSS, CAPACITOR AND STARTOR
- 1x36 W. FLUORESCENT LAMP (HANGING CEILING TYPE) WITH BALLAST LOW LOSS, CAPACITOR AND STARTOR, AT SWITCH "a"
- 1x20 W. COMPACT FLUORESCENT (WALL TYPE, OUTDOOR IP54)
- SWITCH "3" SETS FOR SWITCH "a" TO "c"
- TWO-WAYS SWITCH
- SIMPLEX RECEPTACLE WITH GROUND, 10 A. 220 VAC.
- 20 W. COMPACT FLUORESCENT
- EXHAUST FAN 12"
- OUTDOOR BOLLARD TYPE WITH 20 W. COMPACT FLUORESCENT

- DUPLEX RECEPTACLE WITH GROUND, 10 A. 220 VAC.
- POWER RECEPTACLE 3P+N+E 32 A. 400 VAC.
- HIGH BAY FIXTURE 1x400 W. HIGH PRESSURE SODIUM
- HIGH BAY FIXTURE 1x250 W. HIGH PRESSURE SODIUM
- EMERGENCY LIGHTING 2x55 W. HALOGEN W/SEALED LEAD ACID BATTERY BACKUP 2 HOURS
- AIR CONDITIONING, SPLIT TYPE
- LOAD PANEL 3 PHASE (18 CIRCUITS) WITH MAIN CIRCUIT BREAKER
- LIGHTING CONTROL PANEL
- SECONDARY LINES, 380/220 V 50 MM THW OVERHEAD INSULATED CABLES, 3/4 WIRE
- UNDERGROUND WIRING IN CONDUIT

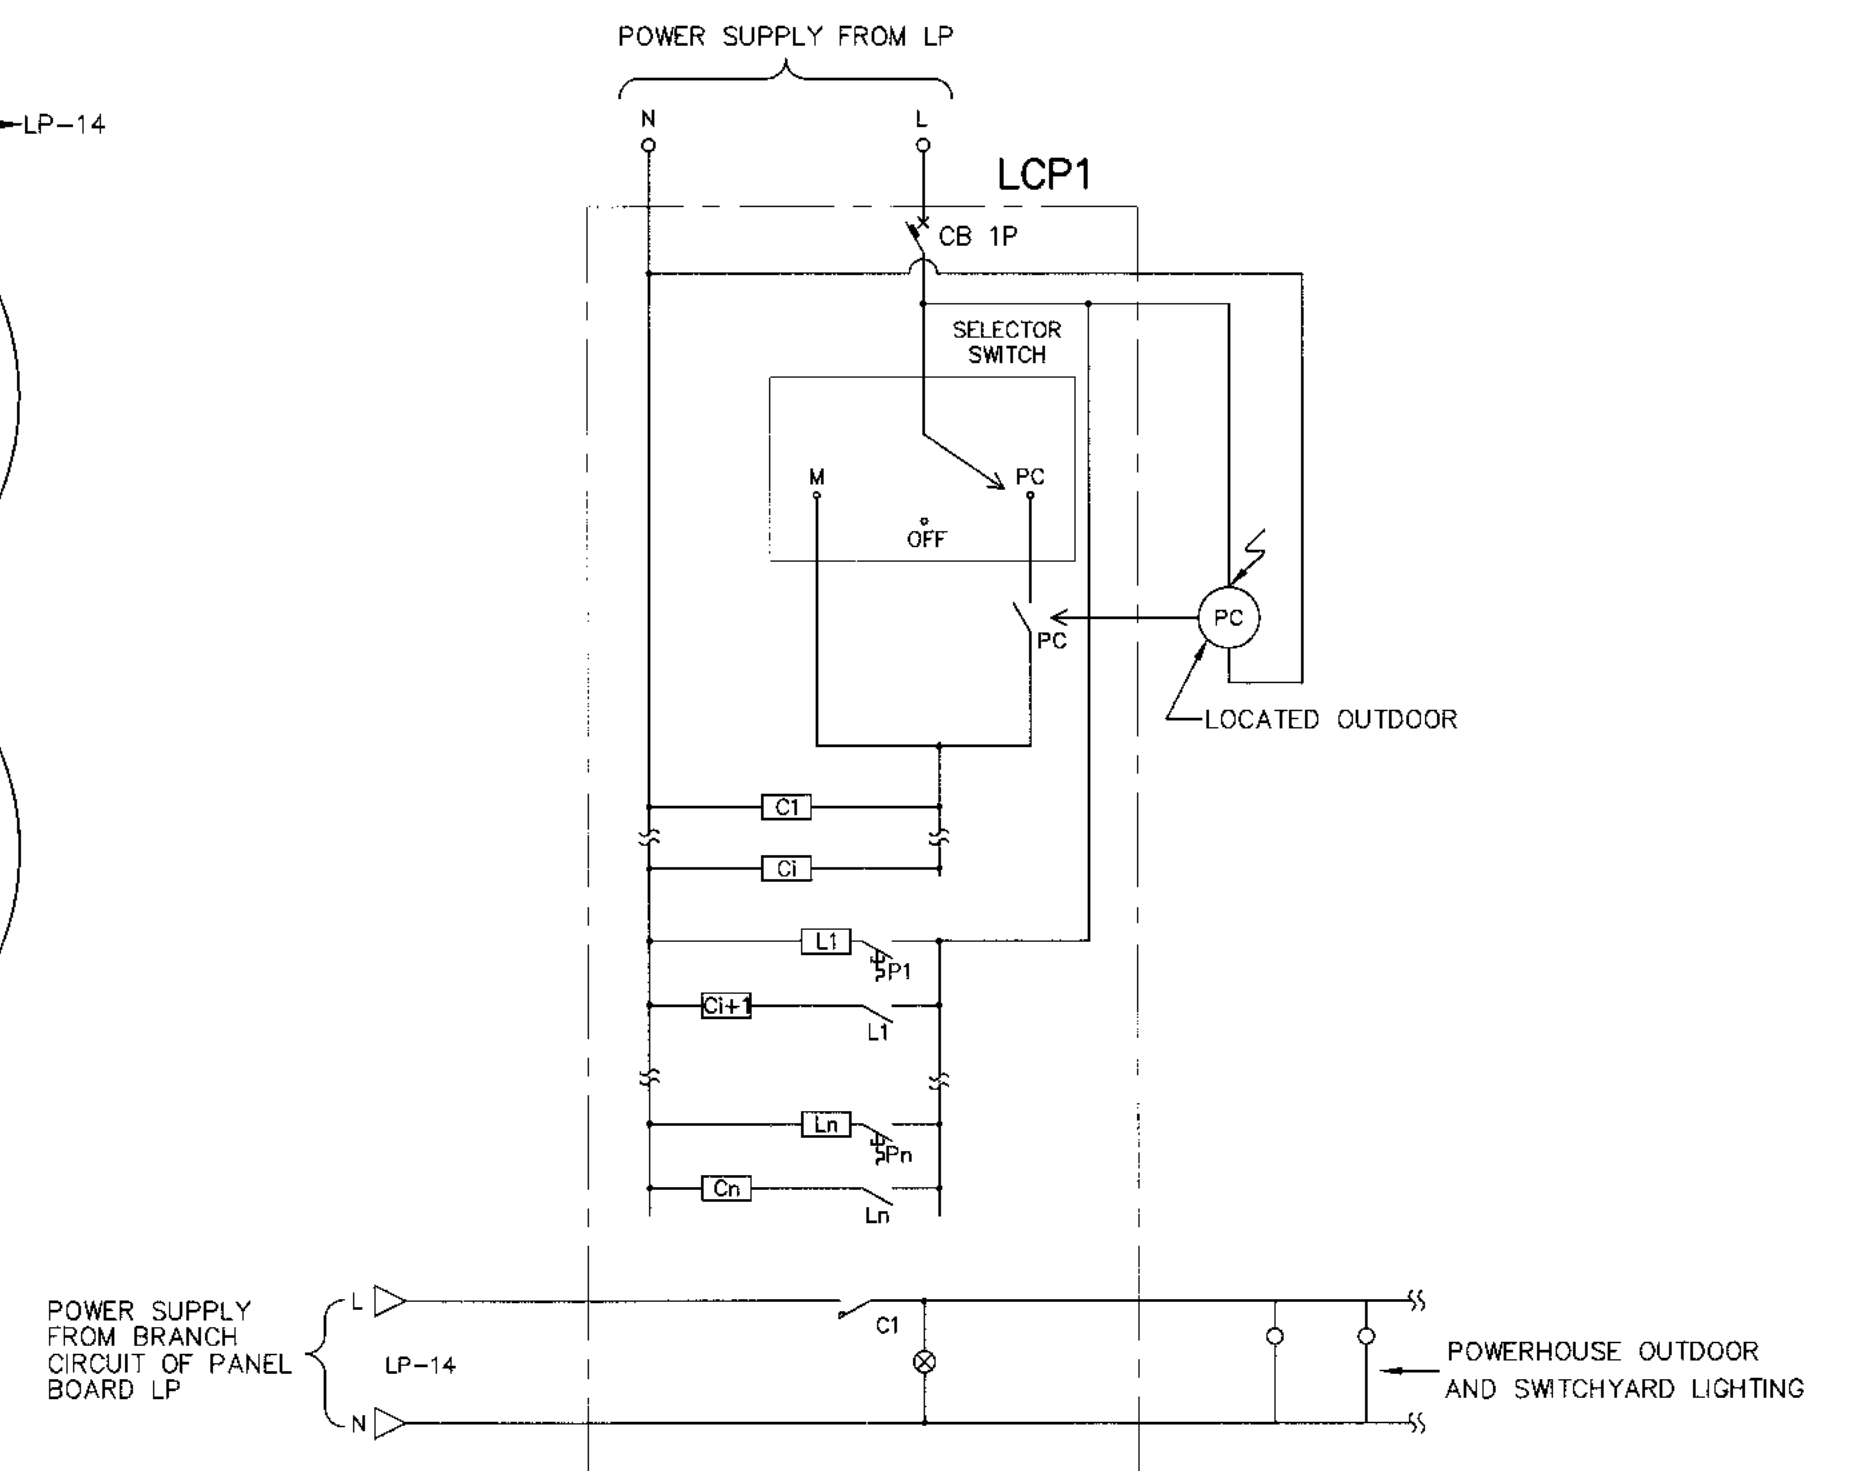



LIGHTING CONTROL PANEL (LCP1) DIAGRAM

LEGEND :

- = PHOTO CELL
- = PHOTO CELL SWITCH CONTACT
- = MAGNETIC CONTACTOR n : 1, 2, 3...
- = LATCHING CONTACTOR n : 1, 2, 3...
- = PUSH BUTTON SWITCH, NON-LATCHED TYPE
- = MAGNETIC RELAY n : 1, 2, 3...
- = LATCHING RELAY n : 1, 2, 3...

3				
2				
1				
NO.	DATE	REVISIONS	CHECKED	APPROVED


KINGDOM OF THAILAND Department of Alternative Energy Development and Efficiency MINISTRY OF ENERGY	
KLONG LAM PLOK HYDROPOWER PROJECT	
CIVIL WORKS AND TRANSMISSION LINE POWERHOUSE ELECTRIC AND LIGHTING SYSTEMS (SHEET 2/4)	
DESIGNED DRAWN CHECKED PROJECT MANAGER	REVIEWED SUBMITTED RECOMMENDED APPROVED DATE 08/03/2559
P&C MANAGEMENT CO.,LTD.	DEPARTMENT OF ALTERNATIVE ENERGY DEVELOPMENT AND EFFICIENCY MINISTRY OF ENERGY
DRAWING NO. KLP-PH-21	SHEET NO. 93 OF 110

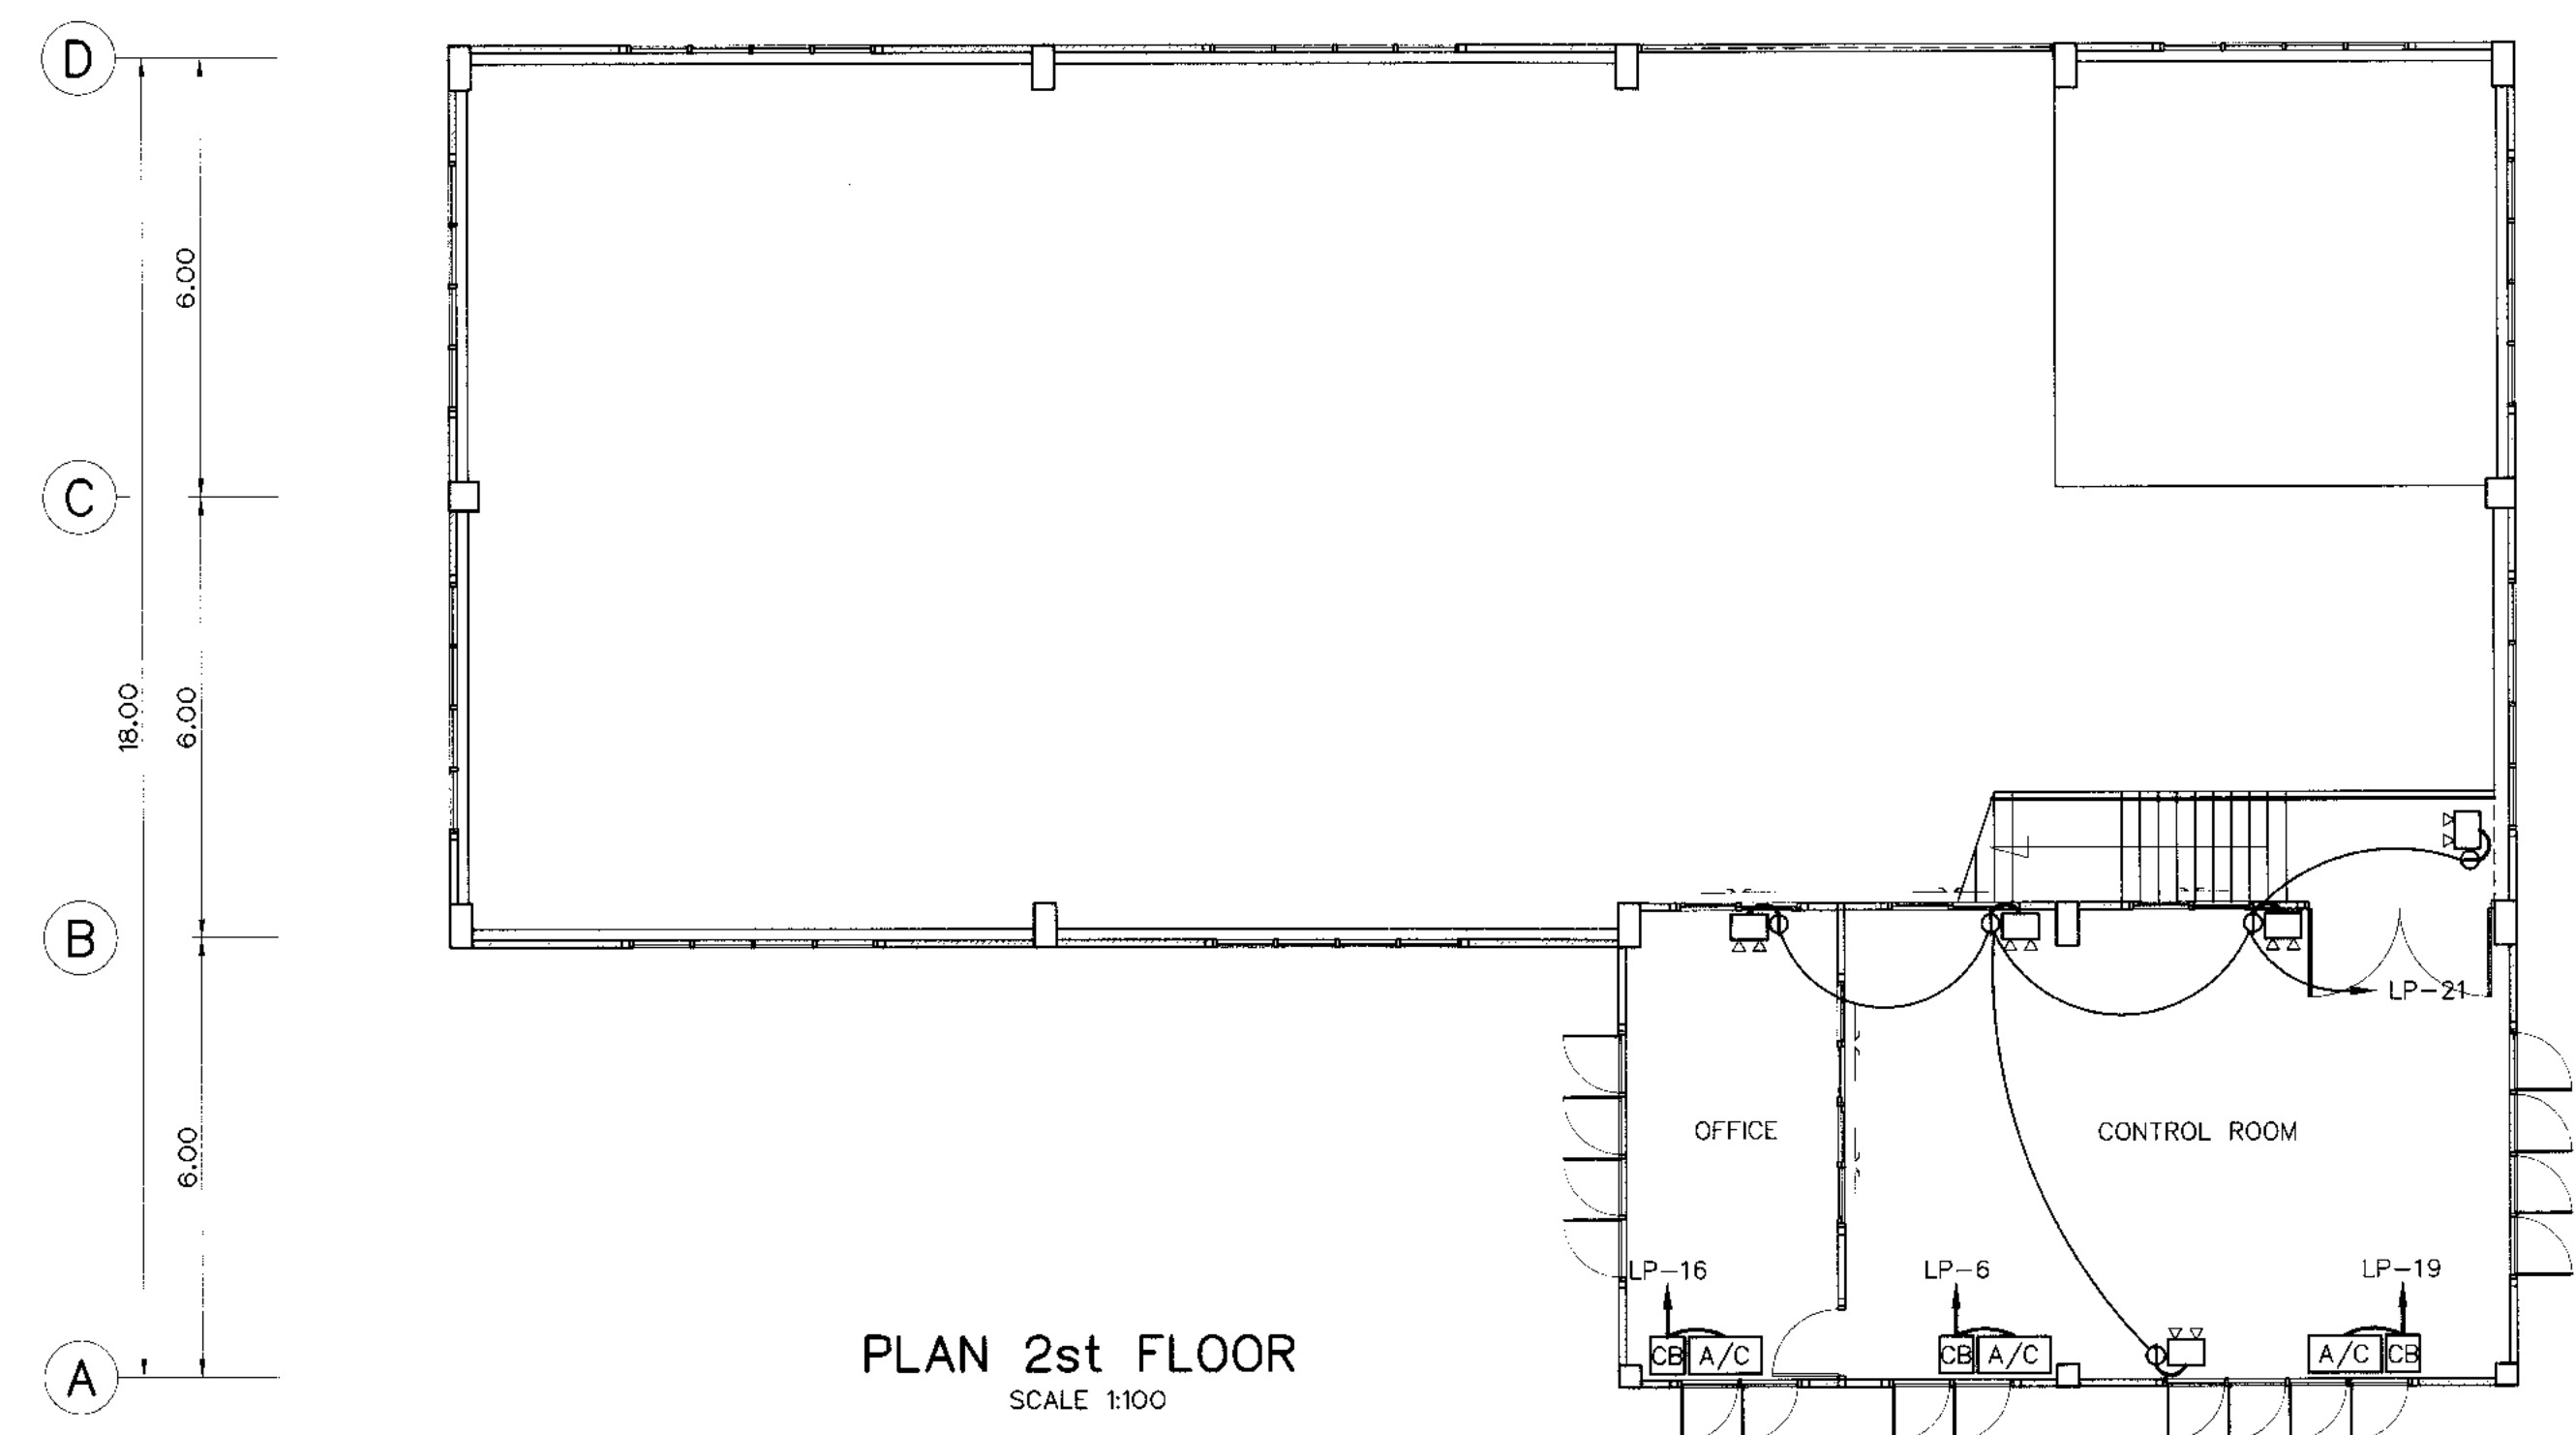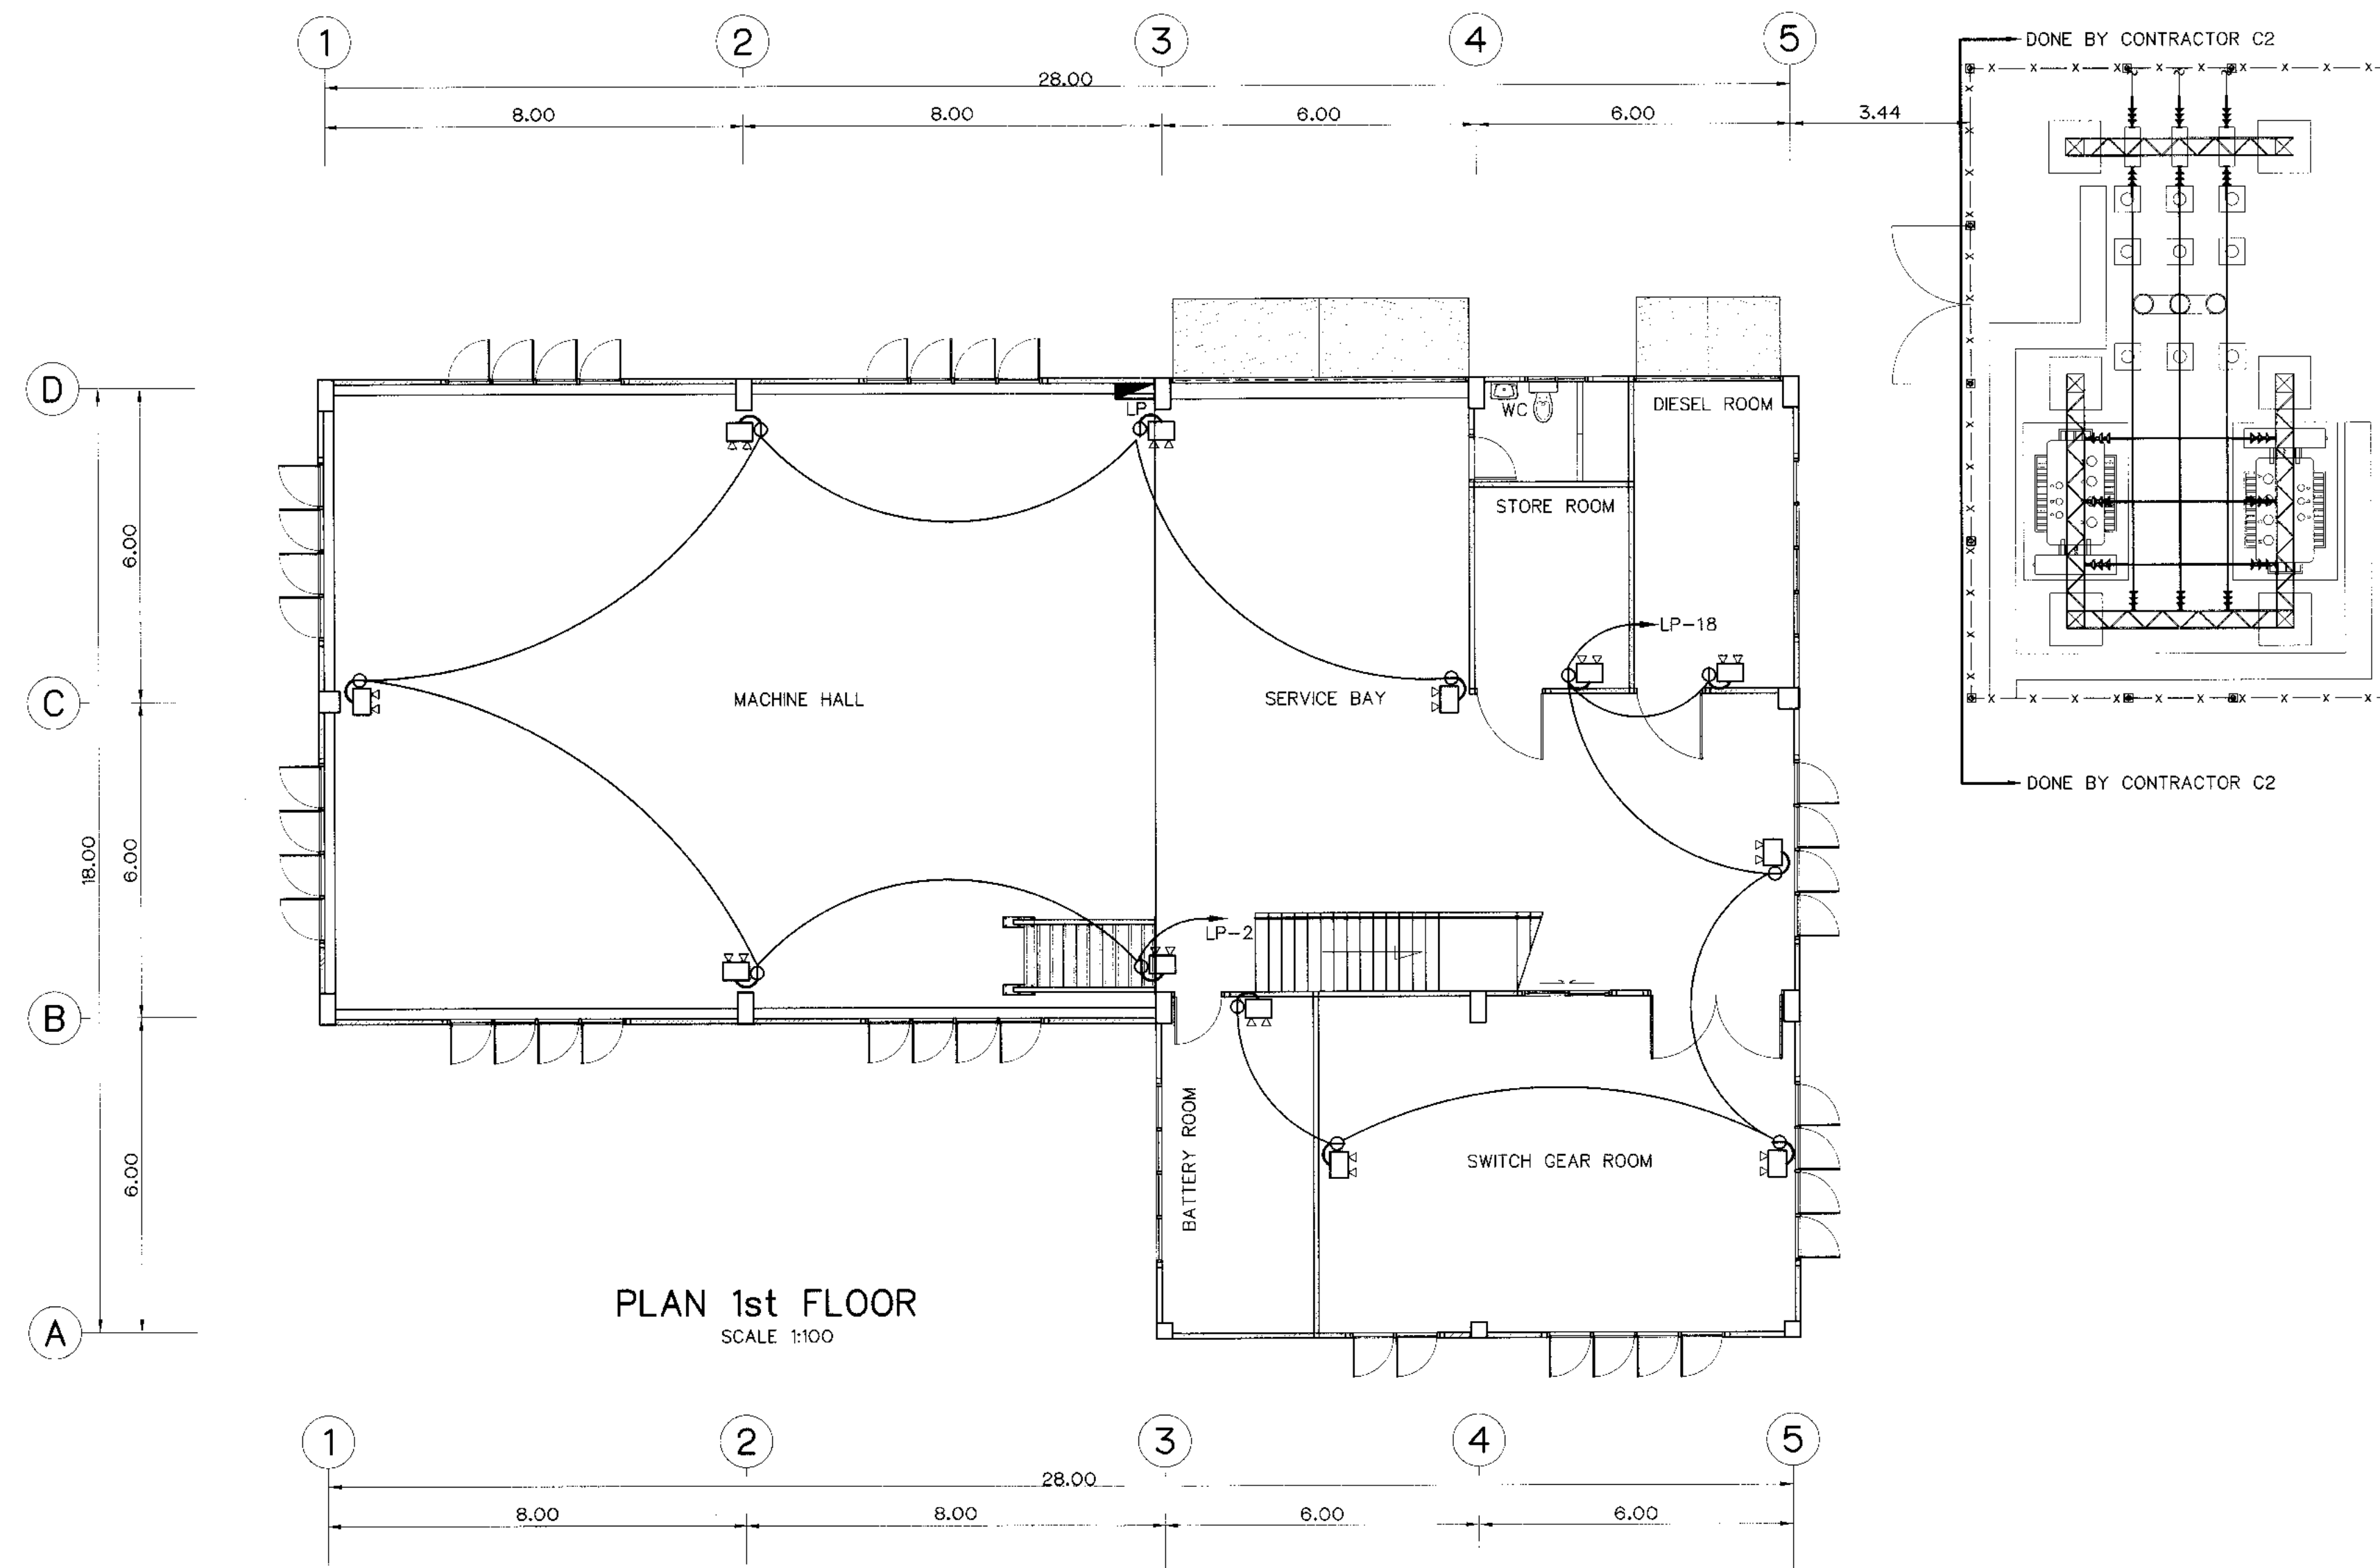

LEGENDS :

- 2x36 W. FLUORESCENT LAMP (HANGING OR CEILING TYPE) WITH BALLAST LOW LOSS, CAPACITOR AND STARTOR AT SWITCH "a"
- 2x36 W. FLUORESCENT LAMP (CORROSION PROOF) WITH BALLAST LOW LOSS, CAPACITOR AND STARTOR
- 1x36 W. FLUORESCENT LAMP (HANGING CEILING TYPE) WITH BALLAST LOW LOSS, CAPACITOR AND STARTOR, AT SWITCH "a"
- 1x20 W. COMPACT FLUORESCENT (WALL TYPE, OUTDOOR IP54)
- SWITCH "3" SETS FOR SWITCH "a" TO "c"
- TWO-WAYS SWITCH
- SIMPLEX RECEPTACLE WITH GROUND, 10 A. 220 VAC.
- 20 W. COMPACT FLUORESCENT
- EXHAUST FAN 12"
- OUTDOOR BOLLARD TYPE WITH 20 W. COMPACT FLUORESCENT
- DUPLEX RECEPTACLE WITH GROUND, 10 A. 220 VAC.
- POWER RECEPTACLE 3P+N+E 32 A. 400 VAC.
- HIGH BAY FIXTURE 1x400 W. HIGH PRESSURE SODIUM
- HIGH BAY FIXTURE 1x250 W. HIGH PRESSURE SODIUM
- EMERGENCY LIGHTING 2x55 W. HALOGEN W/SEALED LEAD ACID BATTERY BACKUP 2 HOURS
- AIR CONDITIONING, SPLIT TYPE
- LOAD PANEL 3 PHASE (18 CIRCUITS) WITH MAIN CIRCUIT BREAKER
- LIGHTING CONTROL PANEL
- SECONDARY LINES, 380/220 V 50 MM THW OVERHEAD INSULATED CABLES, 3Ø 4 WIRE UNDERGROUND WIRING IN CONDUIT

KINGDOM OF THAILAND Department of Alternative Energy Development and Efficiency MINISTRY OF ENERGY			
KLONG LAM PLOK HYDROPOWER PROJECT			
CIVIL WORKS AND TRANSMISSION LINE POWERHOUSE ELECTRIC AND LIGHTING SYSTEMS (SHEET 3/4)			
P&C MANAGEMENT CO.,LTD.		Department of Alternative Energy Development and Efficiency MINISTRY OF ENERGY	
DESIGNED	<i>[Signature]</i>	2016.04	REVIEWED
DRAWN	<i>[Signature]</i>	2016.04	SUBMITTED
CHECKED	<i>[Signature]</i>	2016.04	RECOMMENDED
APPROVED		<i>[Signature]</i>	
PROJECT MANAGER		DATE	DRAWING NO.
		08/03/2559	KLP-PH-22
CONSULTANTS		DEDE	SHEET NO.
			94 OF 110

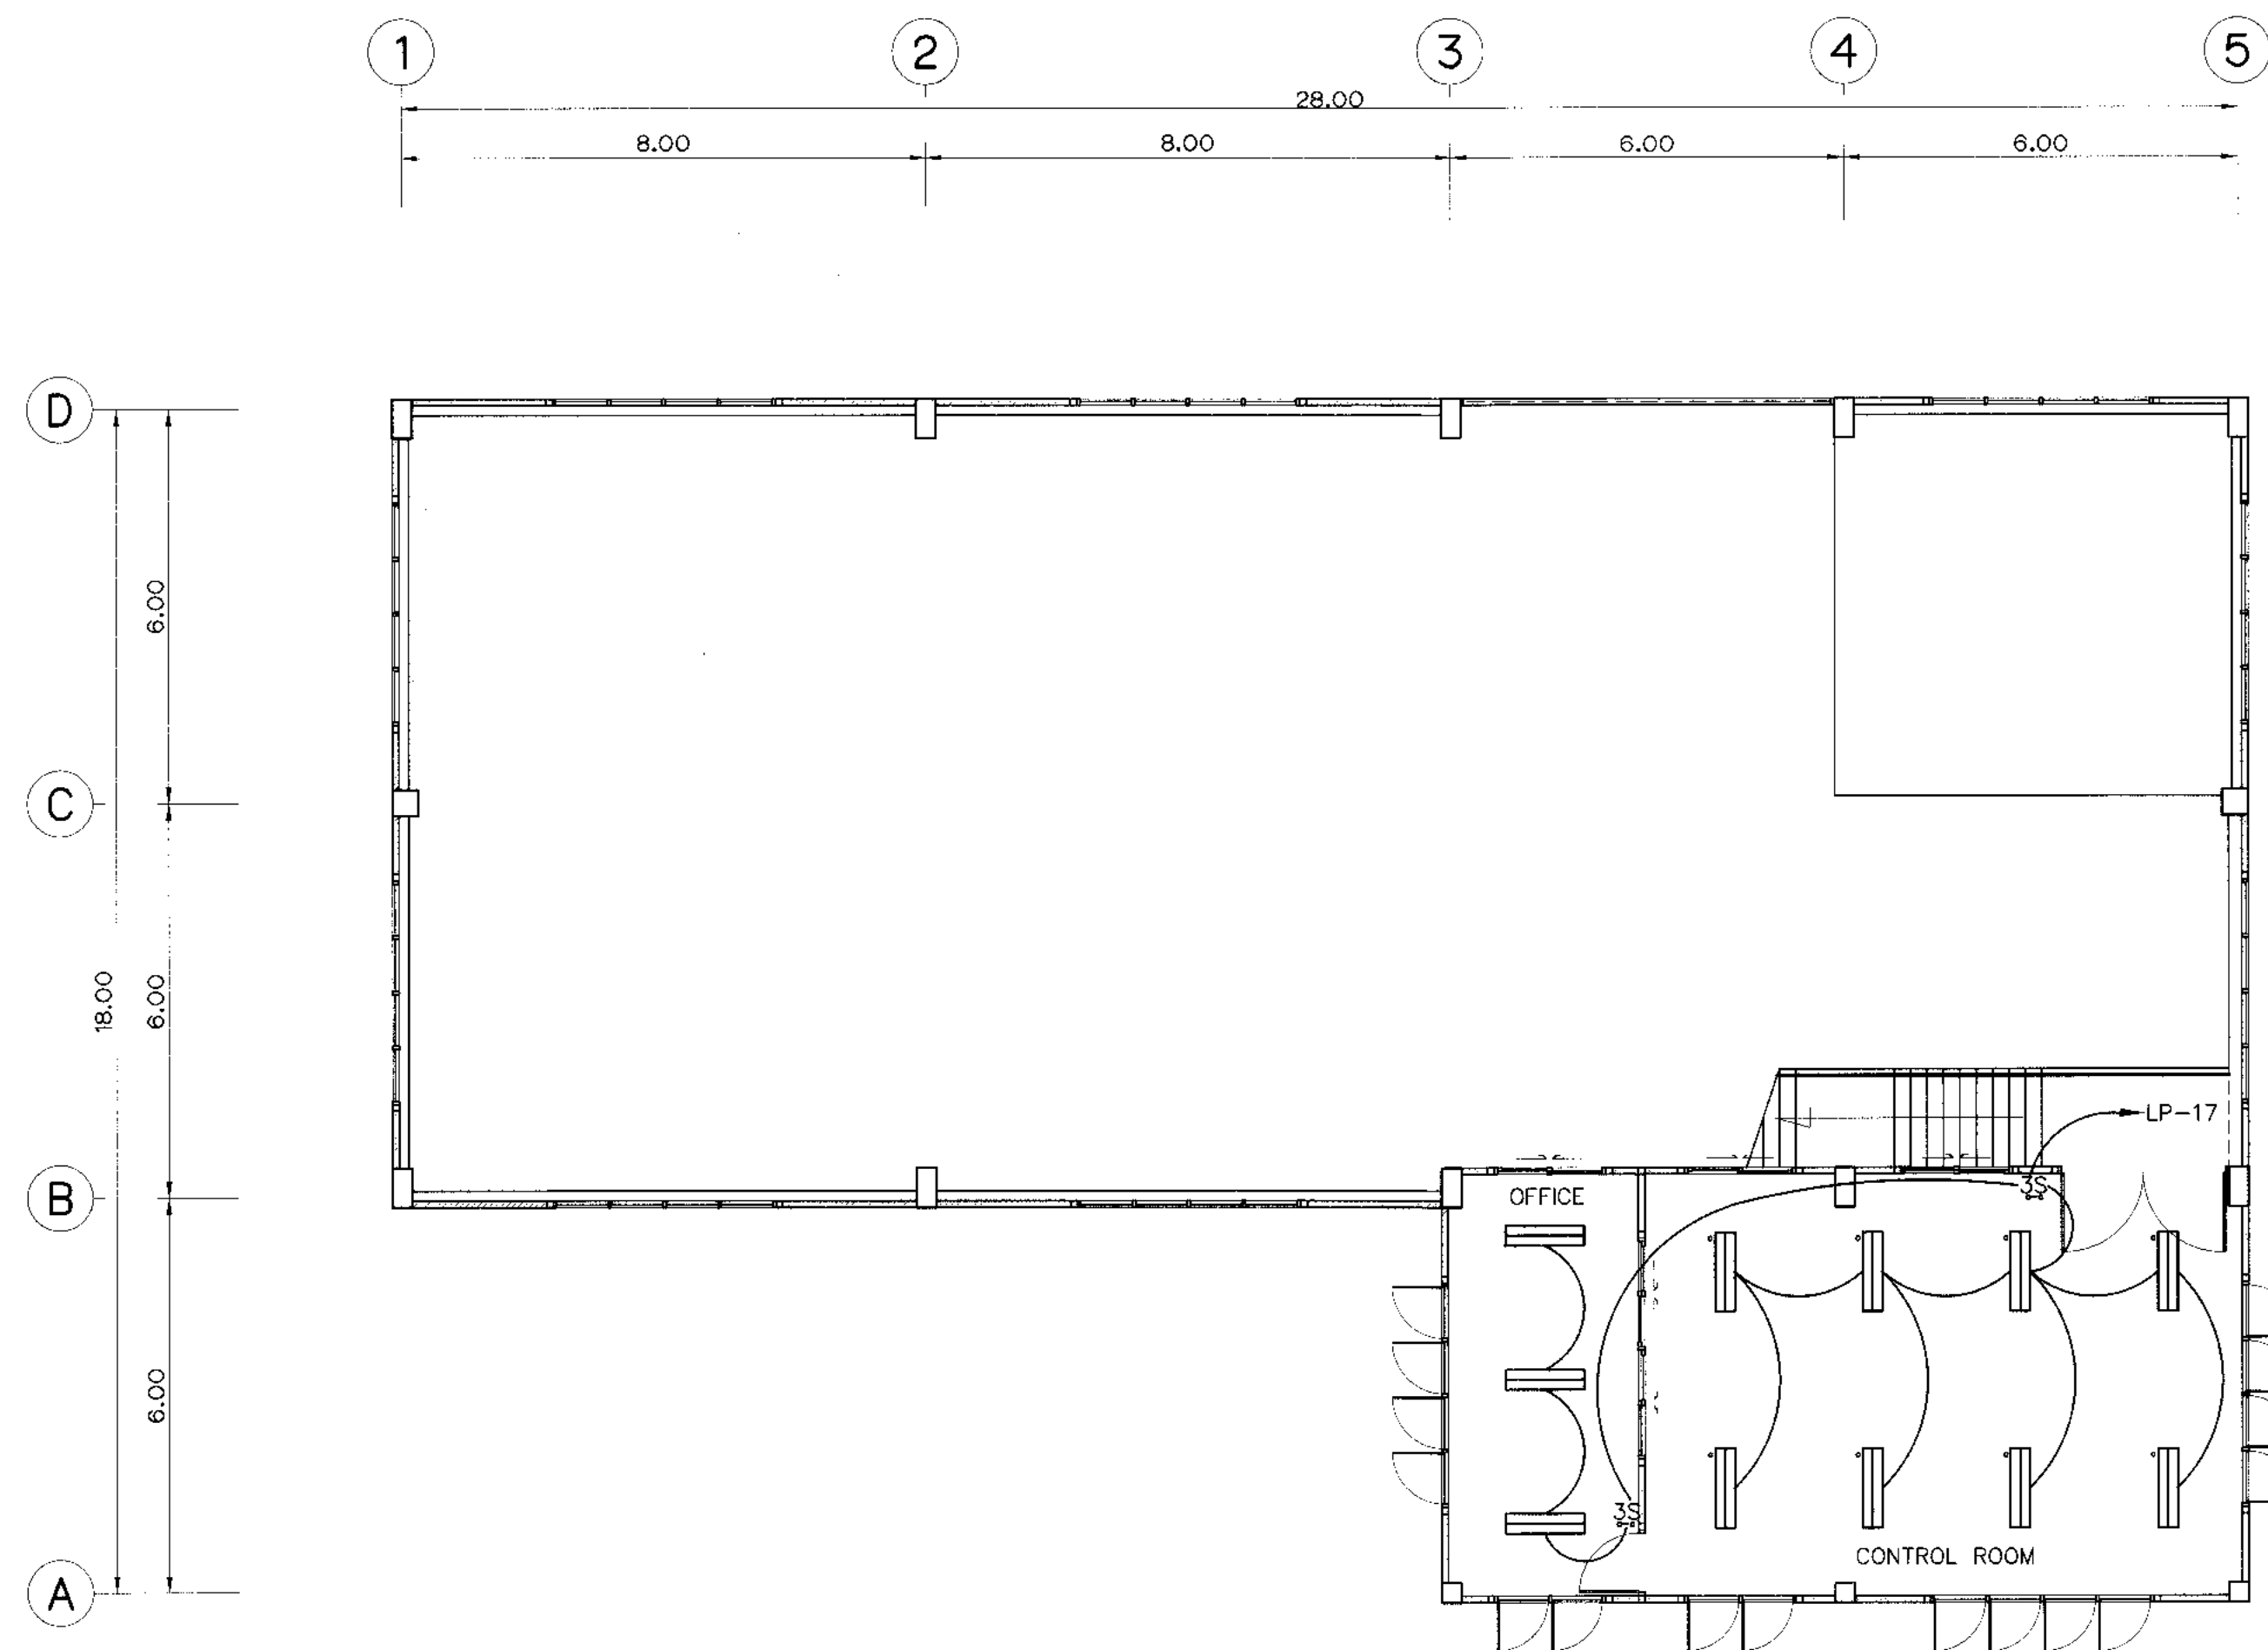

PLAN 2st FLOOR
SCALE 1:100

LEGENDS :

- 2x36 W. FLUORESCENT LAMP (HANGING OR CEILING TYPE) WITH BALLAST LOW LOSS, CAPACITOR AND STARTOR AT SWITCH "o"

2x36 W. FLUORESCENT LAMP (CORROSION PROOF) WITH BALLAST LOW LOSS, CAPACITOR AND STARTOR

1x36 W. FLUORESCENT LAMP (HANGING CEILING TYPE) WITH BALLAST LOW LOSS, CAPACITOR AND STARTOR, AT SWITCH "d"

1x20 W. COMPACT FLUORESCENT (WALL TYPE, OUTDOOR IP54)

SWITCH "3" SETS FOR SWITCH "o" TO "c"

TWO-WAYS SWITCH

SIMPLEX RECEPTACLE WITH GROUND, 10 A. 220 VAC.

20 W. COMPACT FLUORESCENT

EXHAUST FAN 12"

OUTDOOR BOLLARD TYPE WITH 20 W. COMPACT FLUORESCENT
- DUPLEX RECEPTACLE WITH GROUND, 10 A. 220 VAC.

POWER RECEPTACLE 3P+N+E 32 A. 400 VAC.

HIGH BAY FIXTURE 1x400 W. HIGH PRESSURE SODIUM

HIGH BAY FIXTURE 1x250 W. HIGH PRESSURE SODIUM

EMERGENCY LIGHTING 2x55 W. HALOGEN W/SEALED LEAD ACID BATTERY BACKUP 2 HOURS

AIR CONDITIONING, SPLIT TYPE

LOAD PANEL 3 PHASE (18 CIRCUITS) WITH MAIN CIRCUIT BREAKER

LIGHTING CONTROL PANEL

SECONDARY LINES, 380/220 V 50 MM THW OVERHEAD INSULATED CABLES, 3Ø 4 WIRE

UNDERGROUND WIRING IN CONDUIT


LOAD SCHEDULE OF PANEL BOARD 3Ph 400V 50Hz

PANEL NO. LP		LOCATION : POWERHOUSE									
CCT No.	DESCRIPTION	LOAD IN VA				CIRCUIT BREAKER				kA	
		R	S	T	P	AT	AF				
LP-1	MACHINE HALL LIGHTING 1 (250W HIGHBAY LUMINAIRE)	600				1	10	60	10		
LP-3	MACHINE HALL LIGHTING 2 (250W HIGHBAY LUMINAIRE)		600			1	10	60	10		
LP-5	SERVICE BAY LIGHTING (250W HIGHBAY LUMINAIRE)				600	1	10	60	10		
LP-7	MACHINE HALL POWER RECEPTACLE 1	2,309									
LP-9			2,309			3	16	60	10		
LP-11				2,309							
LP-13	THE FIRST FLOOR RECEPTACLE	3,800				1	25	60	10		
LP-15	THE FIRST FLOOR LIGHTING		1,330			1	10	60	10		
LP-17	THE SECOND FLOOR LIGHTING			880		1	10	60	10		
LP-19	CONTROL ROOM AIR CONDITION NO.2 36,000 BTU/HR	4,250				1	25	60	10		
LP-21	THE SECOND FLOOR EMERGENCY LIGHTING		1,000			1	10	60	10		
LP-23	INDOOR HALL AREA LIGHTING (150W HIGHBAY LUMINAIRE)			400		1	10	60	10		
LP-2	MACHINE HALL EMERGENCY LIGHTING	1,200				1	10	60	10		
LP-4	THE SECOND FLOOR RECEPTACLE		2,400			1	16	60	10		
LP-6	CONTROL ROOM AIR CONDITION NO.1 36,000 BTU/HR			4,250		1	25	60	10		
LP-8	MACHINE HALL POWER RECEPTACLE 2	2,309									
LP-10			2,309			3	16	60	10		
LP-12				2,309							
LP-14	OUTDOOR LIGHTING	475				1	10	60	10		
LP-16	OFFICE ROOM AIR CONDITION 24,000 BTU/HR		2,295			1	16	60	10		
LP-18	THE FIRST FLOOR EMERGENCY LIGHTING			1,200		1	10	60	10		
LP-20	MACHINE HALL RECEPTACLE	1,400				1	10	60	10		
LP-22	SPARE		4,600			1	25	60	10		
LP-24	SPARE			4,600		1	25	60	10		
TOTAL LOAD IN VA		16,343	16,843	16,548		3	100	250	25		
			49,734								

3				
2				
1				
NO.	DATE	REVISIONS	CHECKED	APPROVED
		CONSULTANTS	DEDE	

P&C MANAGEMENT CO.,LTD.		REVIEWED	
DESIGNED	27/11/604	SUBMITTED	27/11/604
DRAWN		RECOMMENDED	
CHECKED	27/11/604	APPROVED	
PROJECT MANAGER		DATE	

KLP-PH-23		SHEET NO. 95 OF 110	
-----------	--	---------------------	--

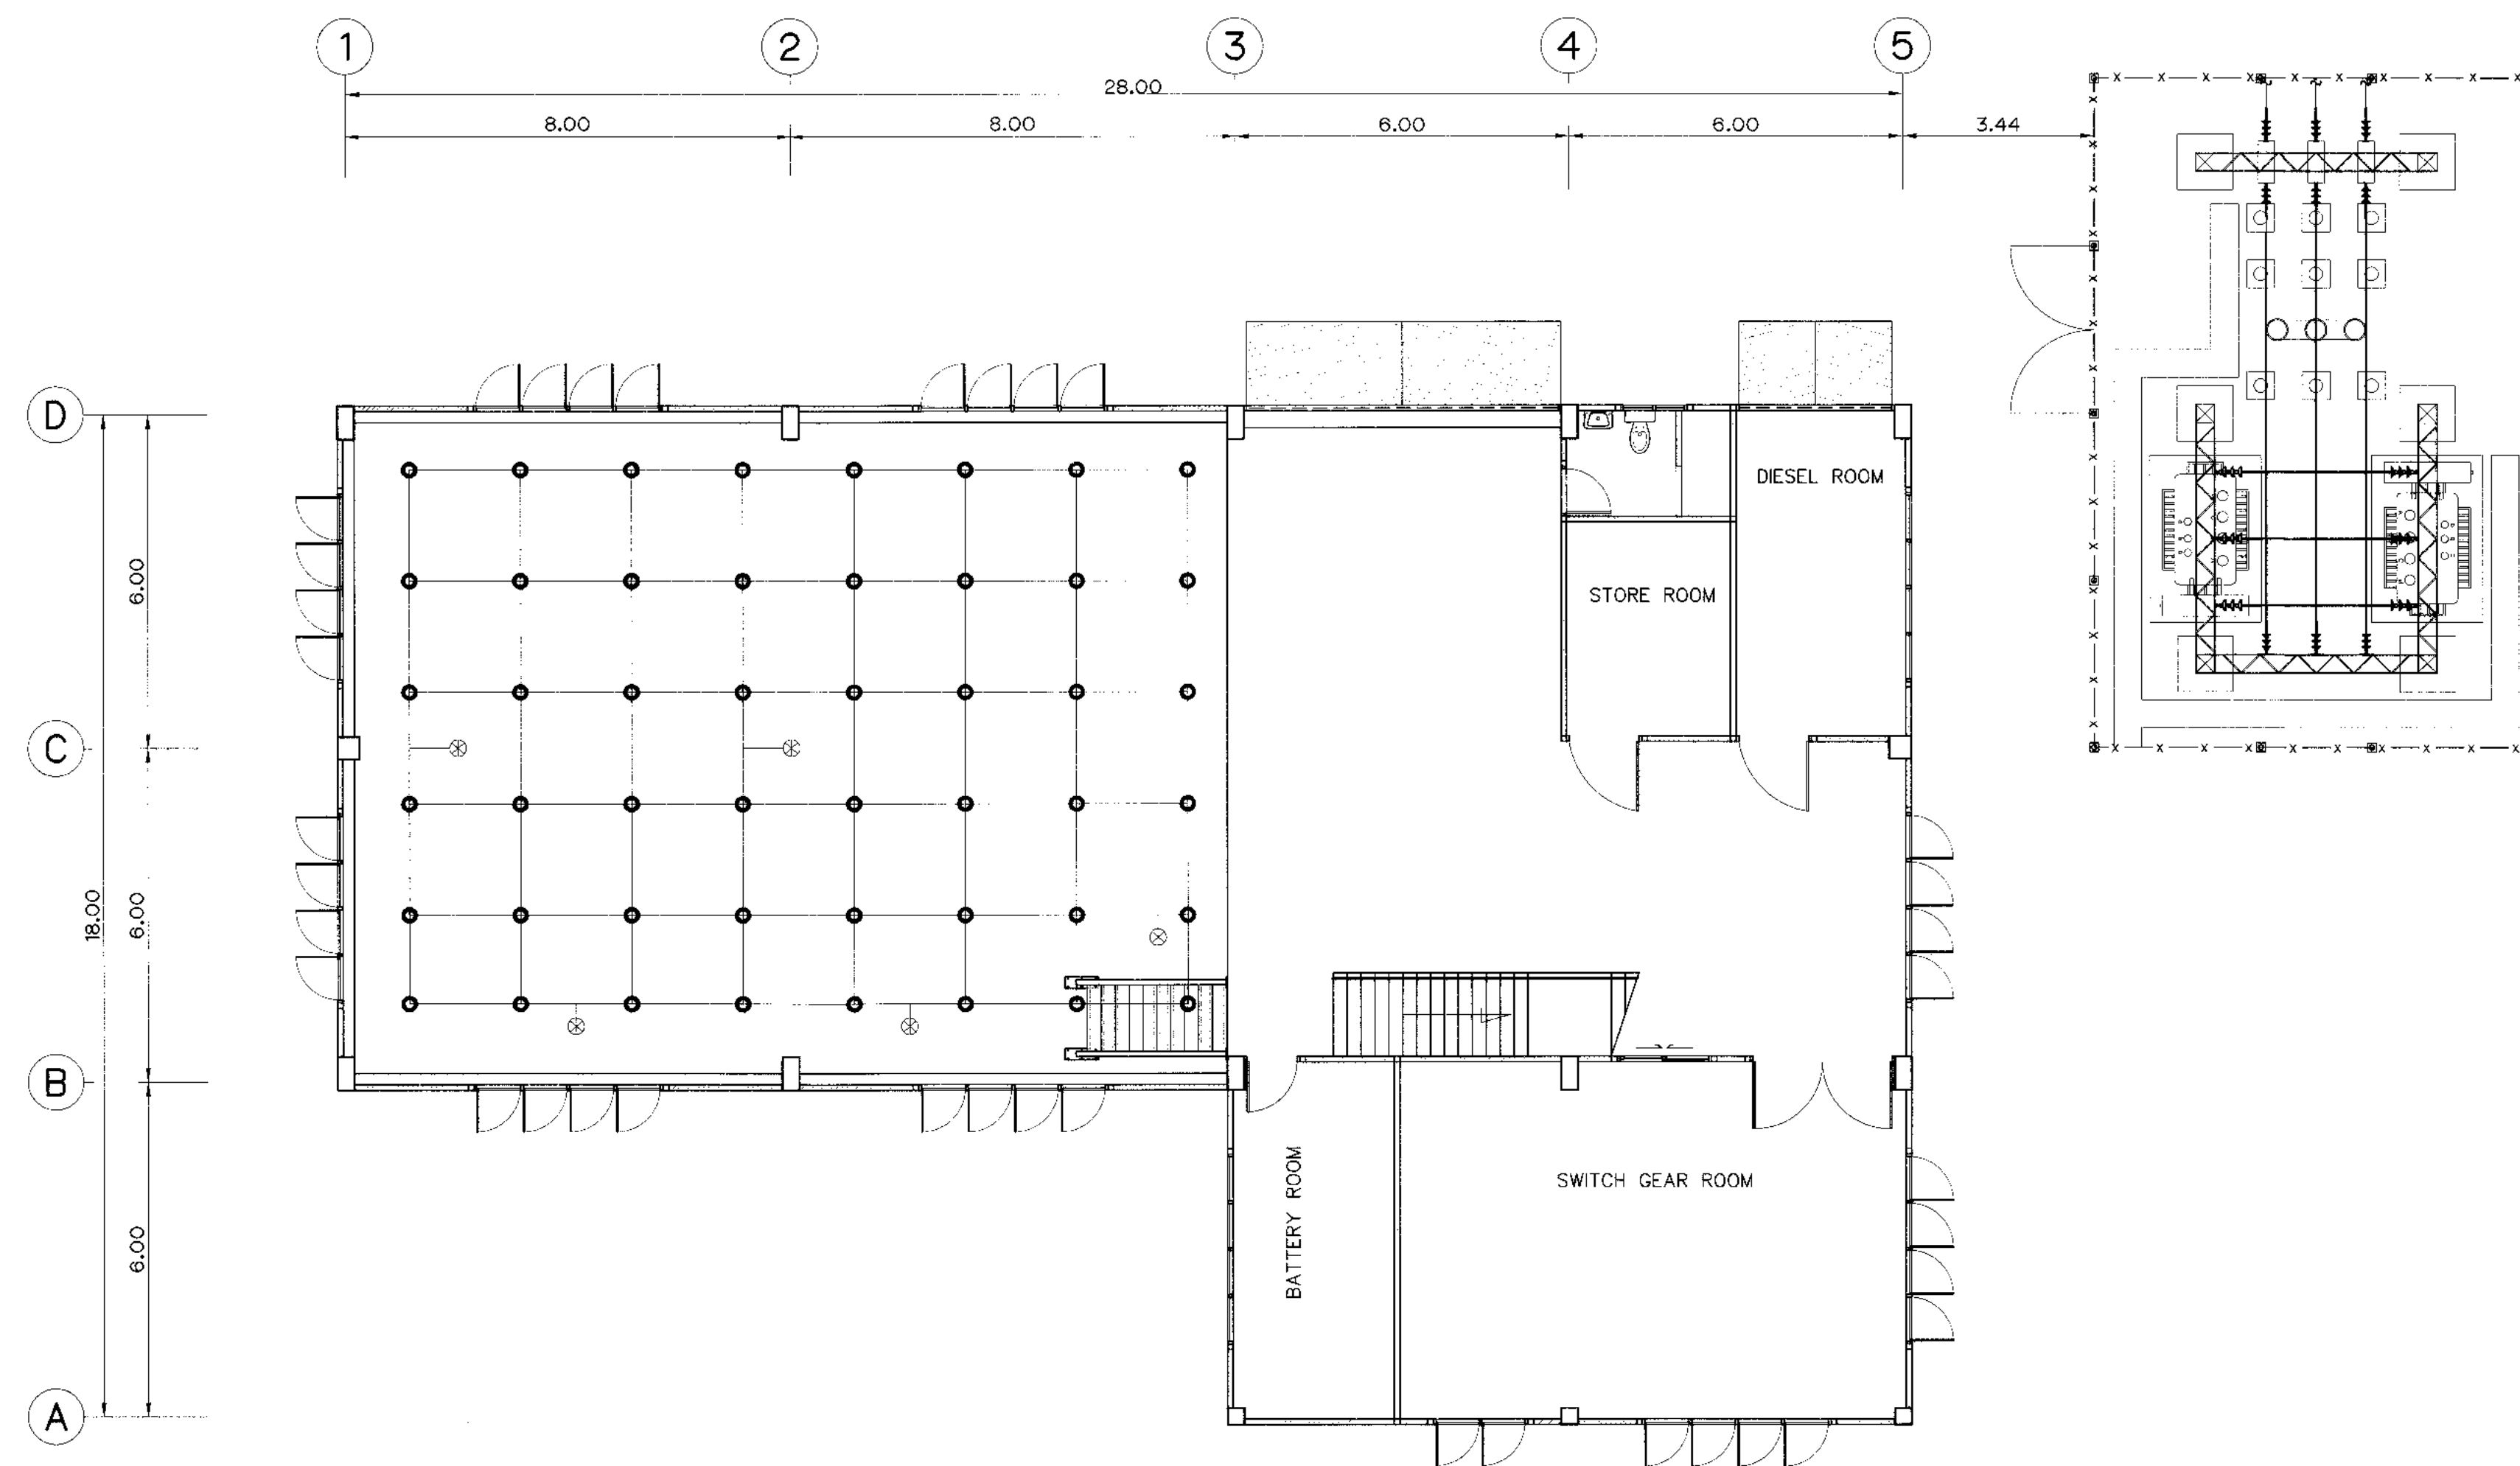

PLAN 1st FLOOR
SCALE 1:100

LEGENDS :

- GROUND ROD
- ⊗ GROUND POINT FOR POWER PLANT EQUIPMENT GROUNDING
- BARE COPPER CONDUCTOR



NOTE

- GROUNDING SYSTEM DONE BY CONTRACTOR C2
- GROUNDING CONDUCTOR, TAP AND RISER FROM GROUNDING NETWORK TO POWER EQUIPMENT SHALL BE FORMED BY BARE COPPER CONDUCTOR NOT LESS THAN 95 SQ.MM.
- GROUNDING SYSTEM RESISTANCE WILL NOT EXCEED 5 OHM.
- CONNECTOR TO WITH IN & BETWEEN THE GROUNDING NETWORK TO POWER PLANT EQUIPMENT WILL BE MADE BY THERMAL CADWELD
- GROUND ROD WILL BE COPPER COVER STEEL DIAMETER 15.87 MM. 2,400 MM. LONG
- THIS DRAWING USE FOR GUIDE ONLY

3				
2				
1				
NO.	DATE	REVISIONS	CHECKED	APPROVED
		CONSULTANTS	DEDE	

KINGDOM OF THAILAND Department of Alternative Energy Development and Efficiency MINISTRY OF ENERGY	
KLONG LAM PLOK HYDROPOWER PROJECT	
CIVIL WORKS AND TRANSMISSION LINE POWERHOUSE GROUNDING SYSTEMS	
P&C MANAGEMENT CO.,LTD.	Department of Alternative Energy Development and Efficiency MINISTRY OF ENERGY
DESIGNED <i>[Signature]</i> 27/11/604	REVIEWED <i>[Signature]</i>
DRAWN <i>[Signature]</i>	SUBMITTED <i>[Signature]</i>
CHECKED <i>[Signature]</i> 27/11/604	APPROVED <i>[Signature]</i>
<i>[Signature]</i> 08/03/2559 PROJECT MANAGER	DRAWING NO. KLP-PH-24 SHEET NO. 96 OF 110

 KINGDOM OF THAILAND Department of Alternative Energy Development and Efficiency MINISTRY OF ENERGY	
KLONG LAM PLOK HYDROPOWER PROJECT	
CIVIL WORKS AND TRANSMISSION LINE	
TAILRACE	
GENERAL LAY-OUT	
 P&C MANAGEMENT CO., LTD.	 Department of Alternative Energy Development and Efficiency MINISTRY OF ENERGY
DESIGNED <i>[Signature]</i> 18.29074 <i>[Signature]</i> 18.29226	REVIEWED <i>[Signature]</i>
DRAWN <i>[Signature]</i>	SUBMITTED <i>[Signature]</i>
CHECKED <i>[Signature]</i> 18.291 18.29226	RECOMMENDED <i>[Signature]</i>
<i>[Signature]</i> PROJECT MANAGER	APPROVED <i>[Signature]</i>
08/03/2559	DRAWING NO.
DATE	KLP-TR-01
	SHEET NO.
	97 OF 110

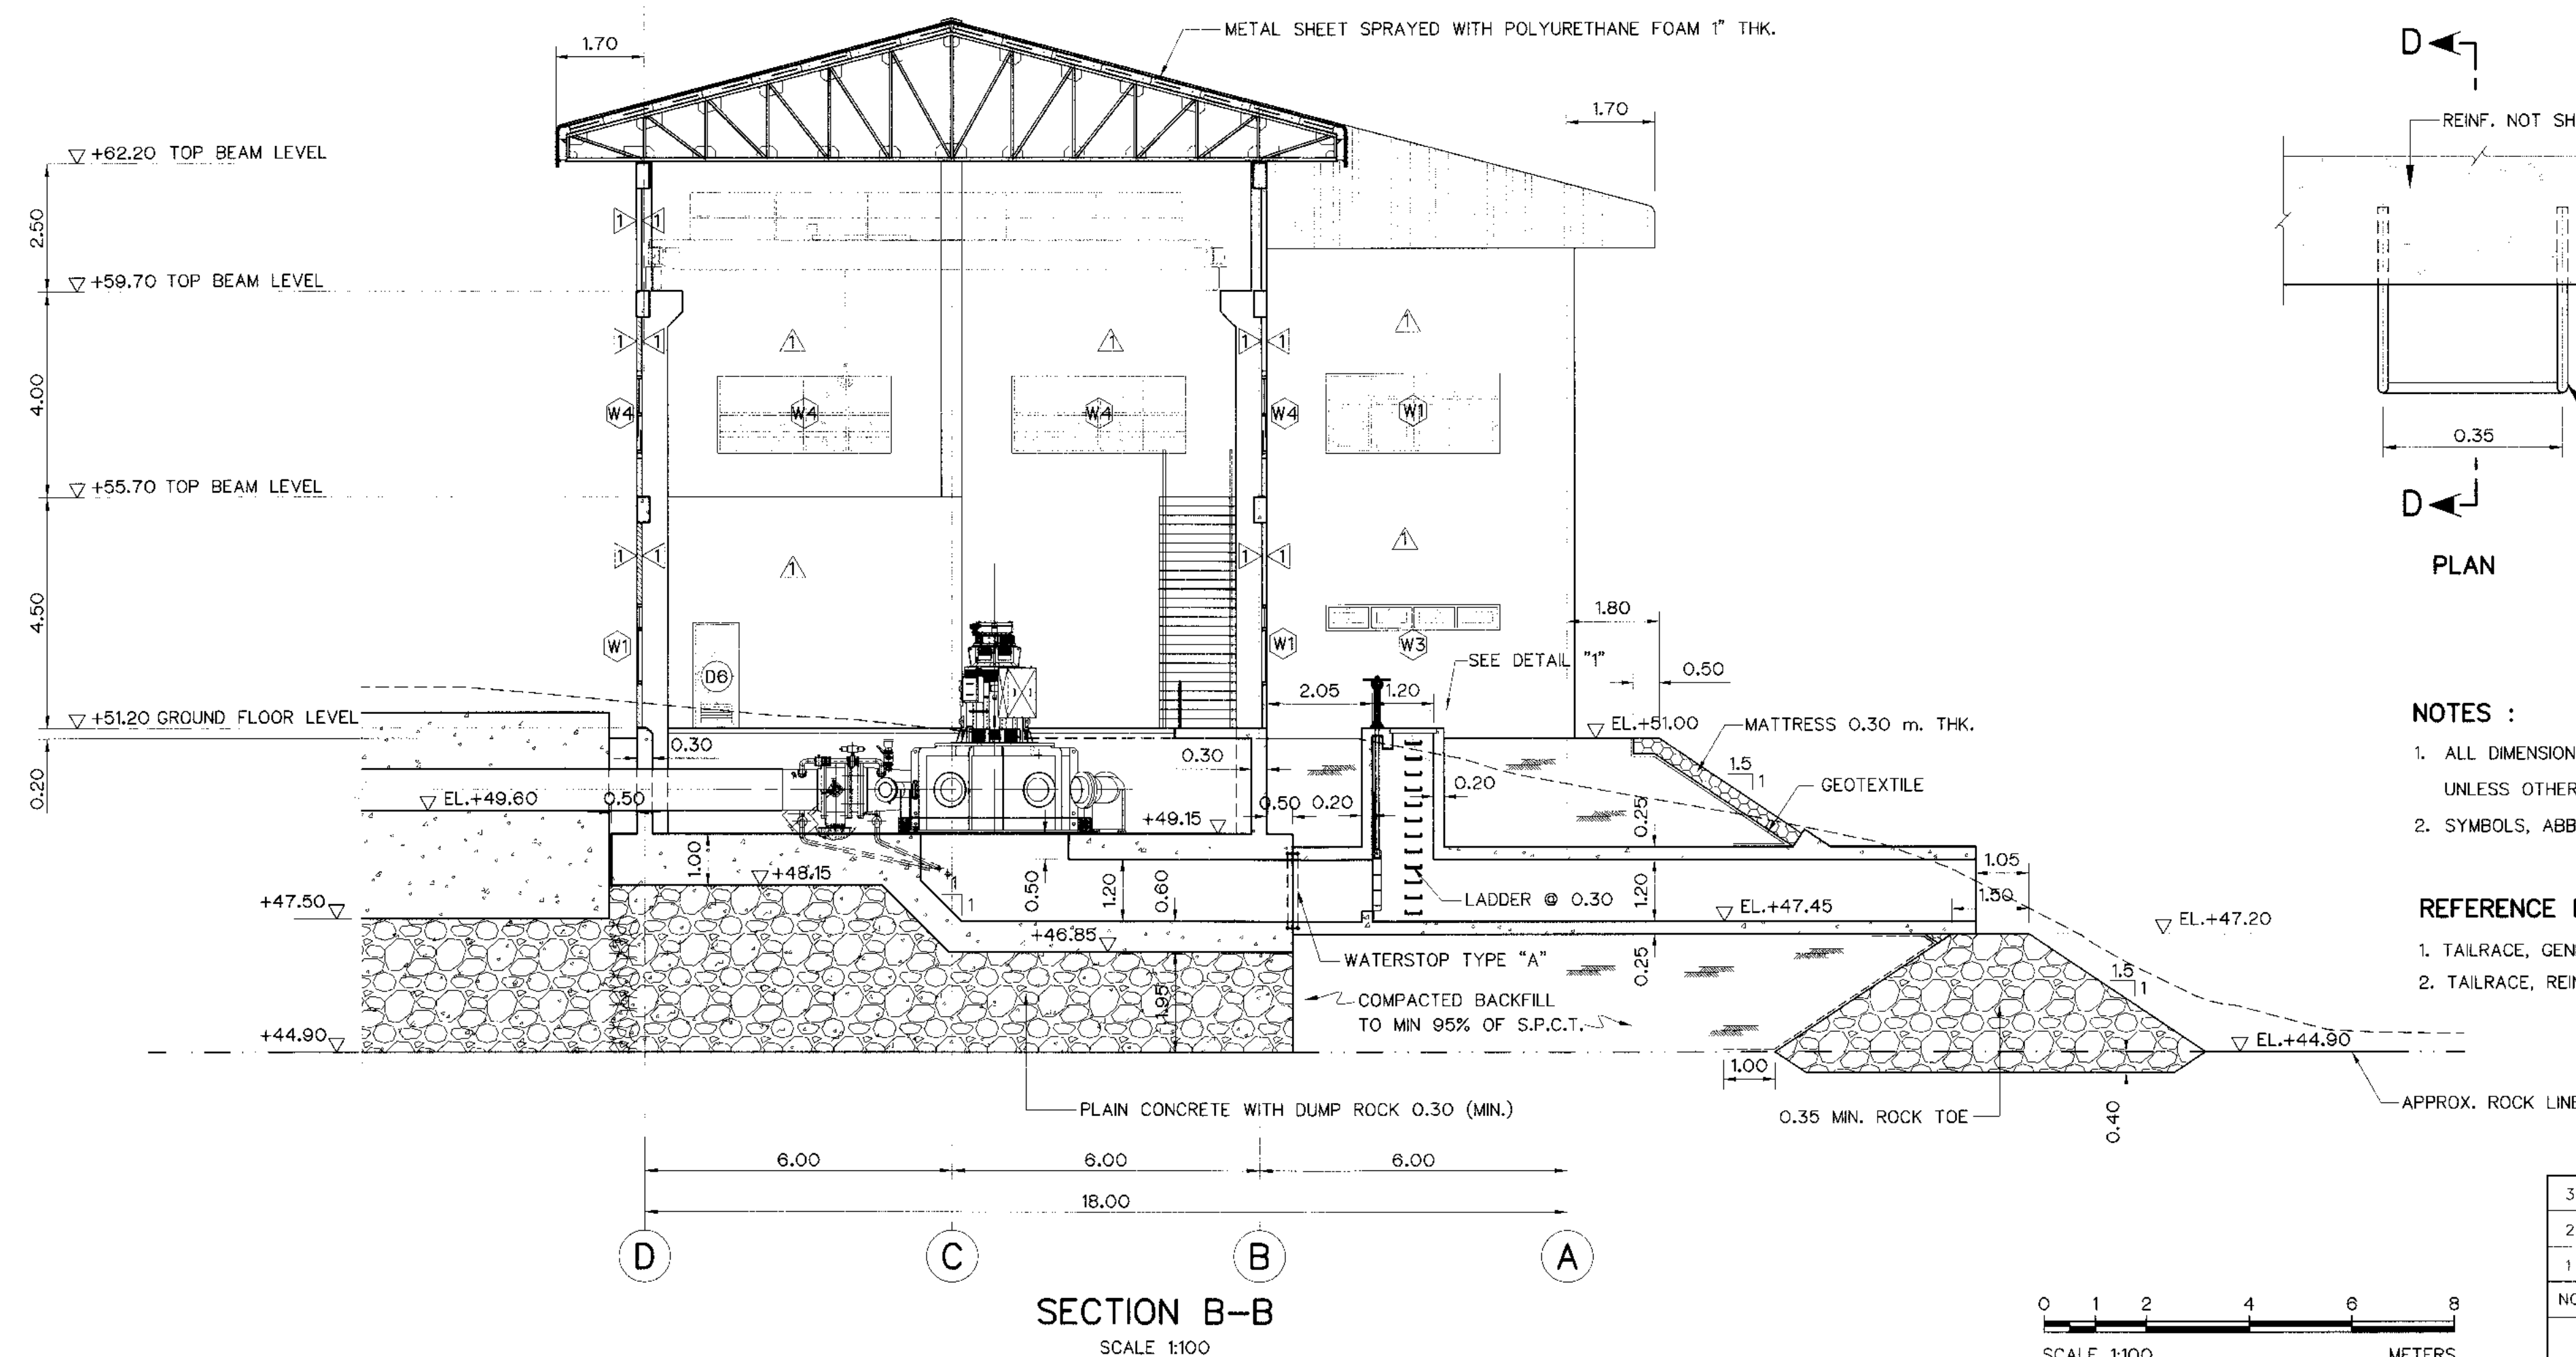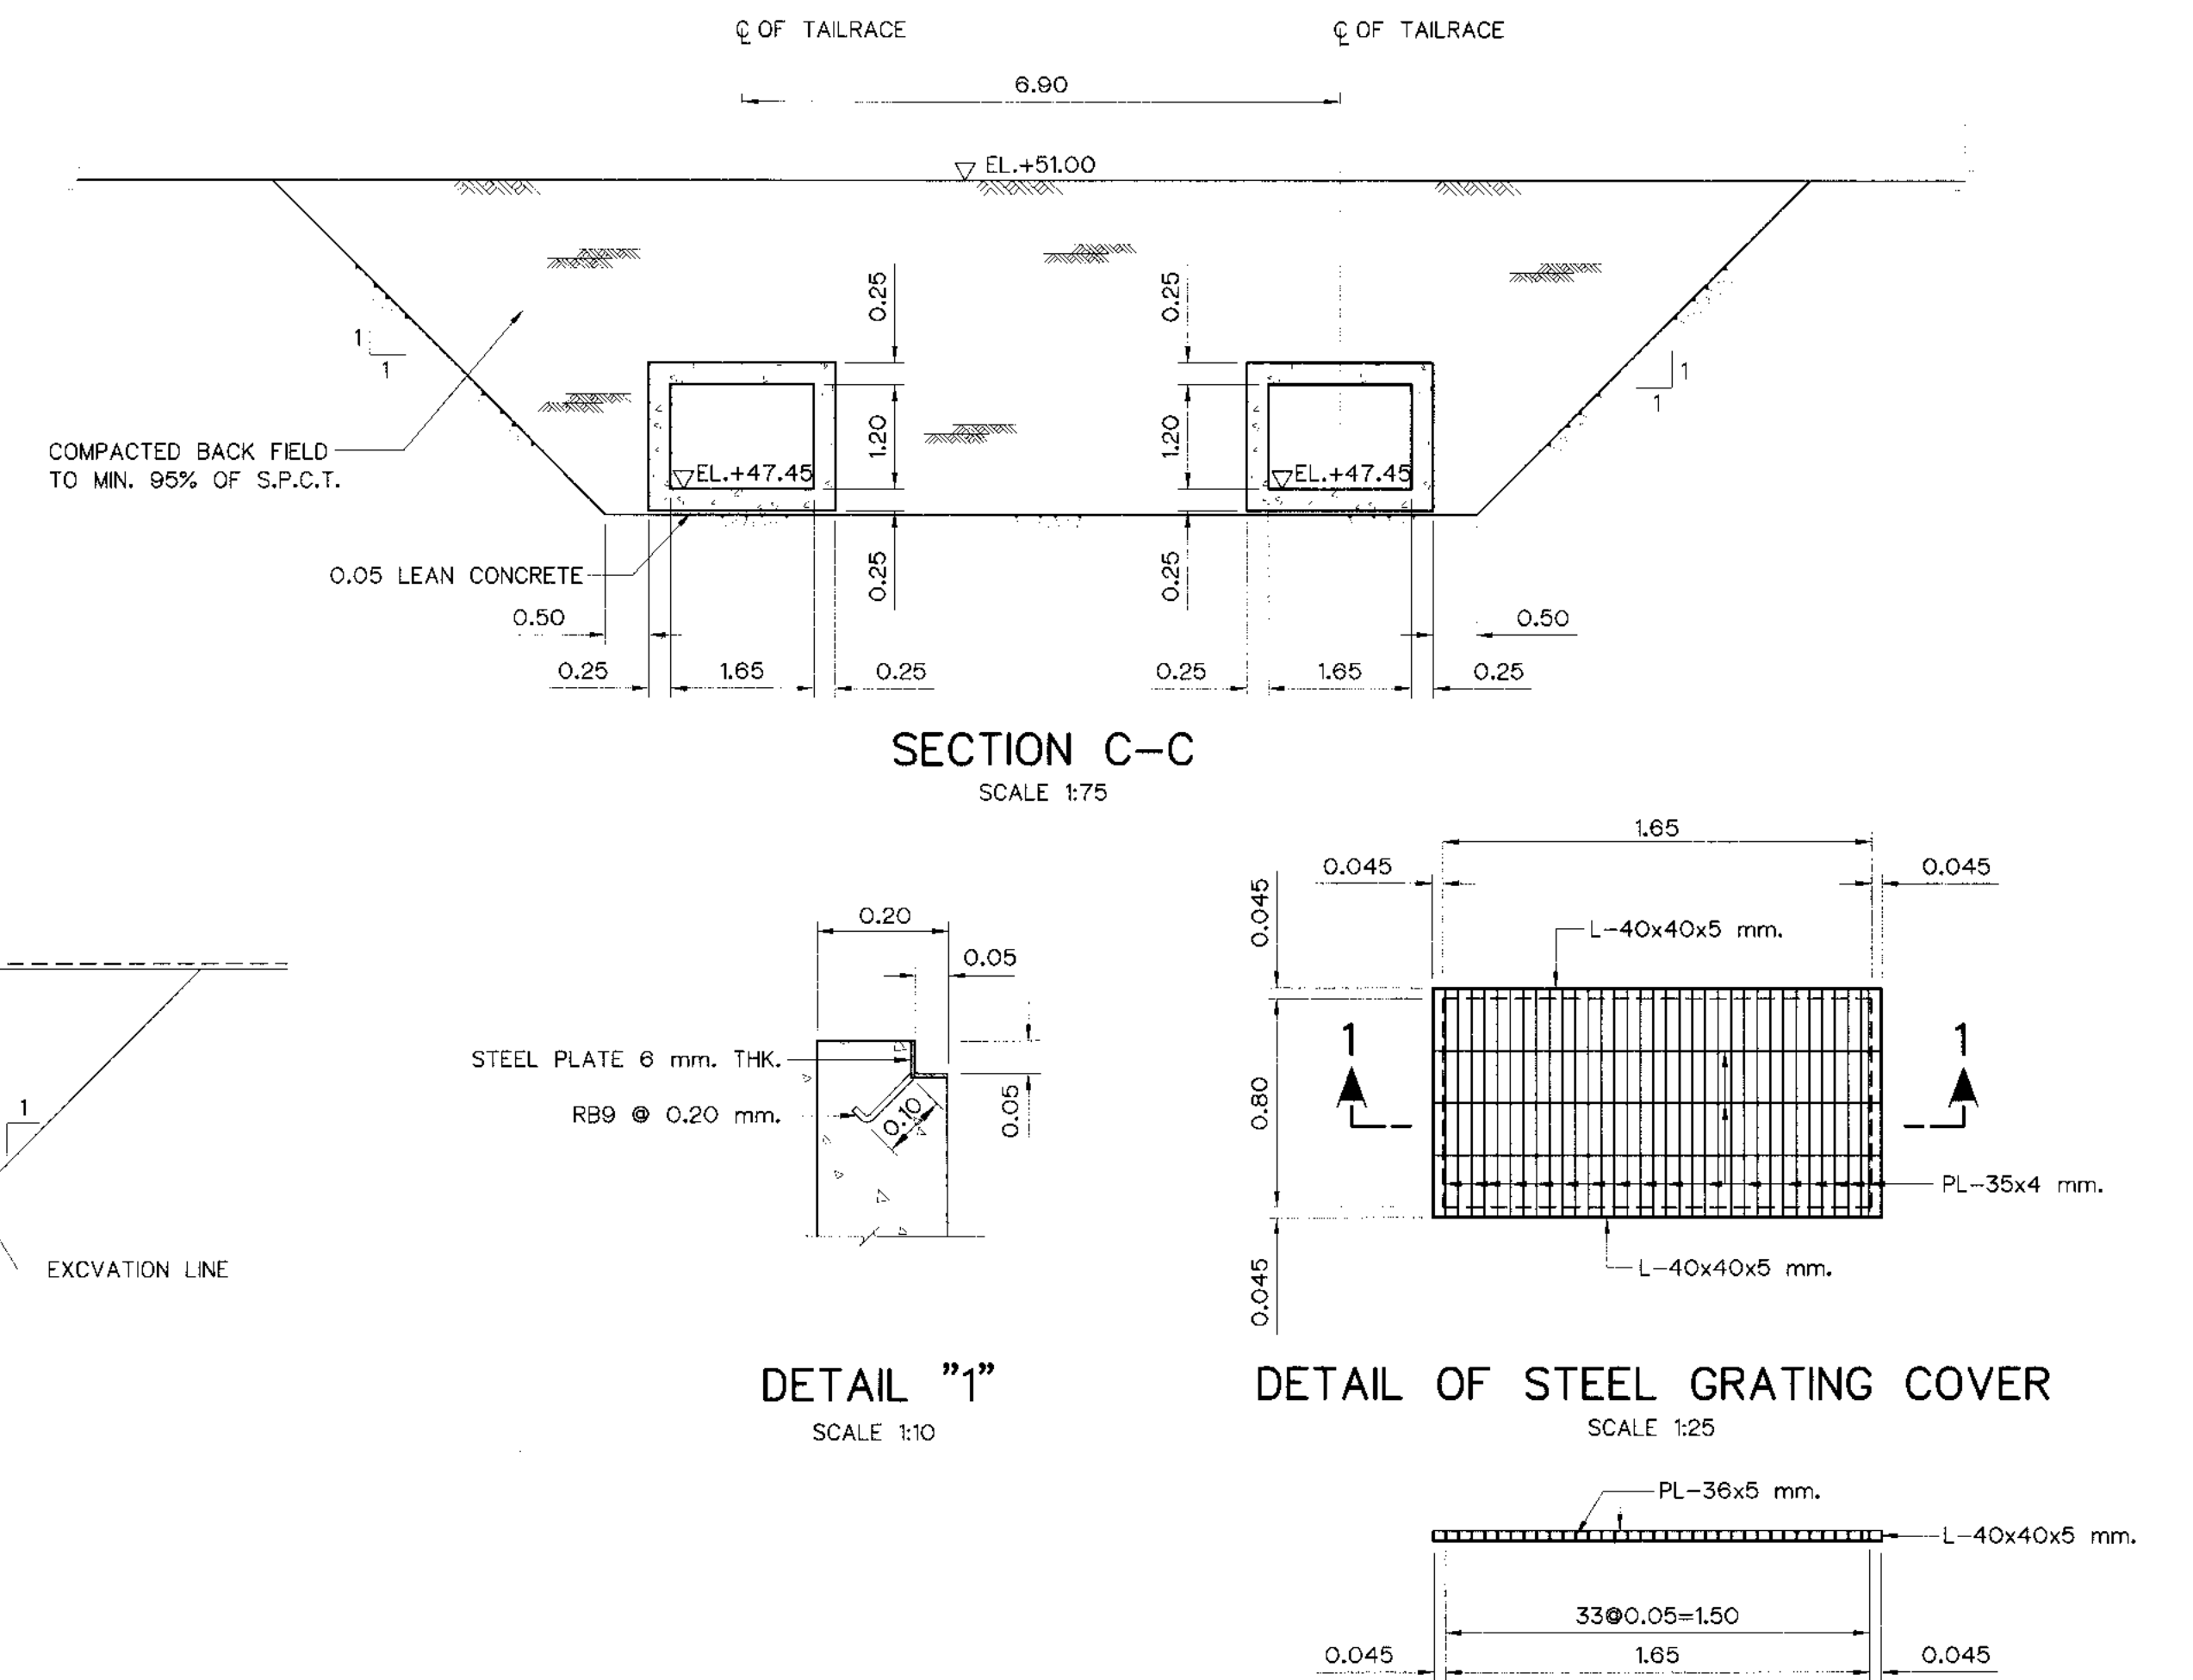






1. ALL DIMENSIONS AND ELEVATIONS (M.S.L.) ARE IN METERS,
UNLESS OTHERWISE SHOWN.
2. SYMBOLS, ABBREVIATIONS AND GENERAL NOTES SEE DWG. NO. KLP-GN-03

1. TAILRACE, GENERAL LAY-OUT
2. TAILRACE, REINFORCEMENT DETAILS

KLP-TR-01
KLP-TR-03

3				
2				
1				
NO.	DATE	REVISIONS	CHECKED	APPROVED
	CONSULTANTS		DEDE	

 KINGDOM OF THAILAND Department of Alternative Energy Development and Efficiency MINISTRY OF ENERGY	
KLONG LAM PLOK HYDROPOWER PROJECT	
CIVIL WORKS AND TRANSMISSION LINE	
TAILRACE	
SECTIONS AND DETAILS	
 P&C MANAGEMENT CO.,LTD.	 Department of Alternative Energy Development and Efficiency MINISTRY OF ENERGY
DESIGNED <i>[Signature]</i> <i>HEL29074</i> <i>05</i> <i>HEL0226</i>	REVISED
DRAWN <i>[Signature]</i>	SUBMITTED <i>[Signature]</i>
CHECKED <i>05</i> <i>HEL0226</i>	RECOMMENDED
<i>02</i> <i>08/03/2559</i>	APPROVED <i>P. Hongsit</i>
PROJECT MANAGER	DRAWING NO. KLP-TR-02
DATE	SHEET NO. 98 of 110

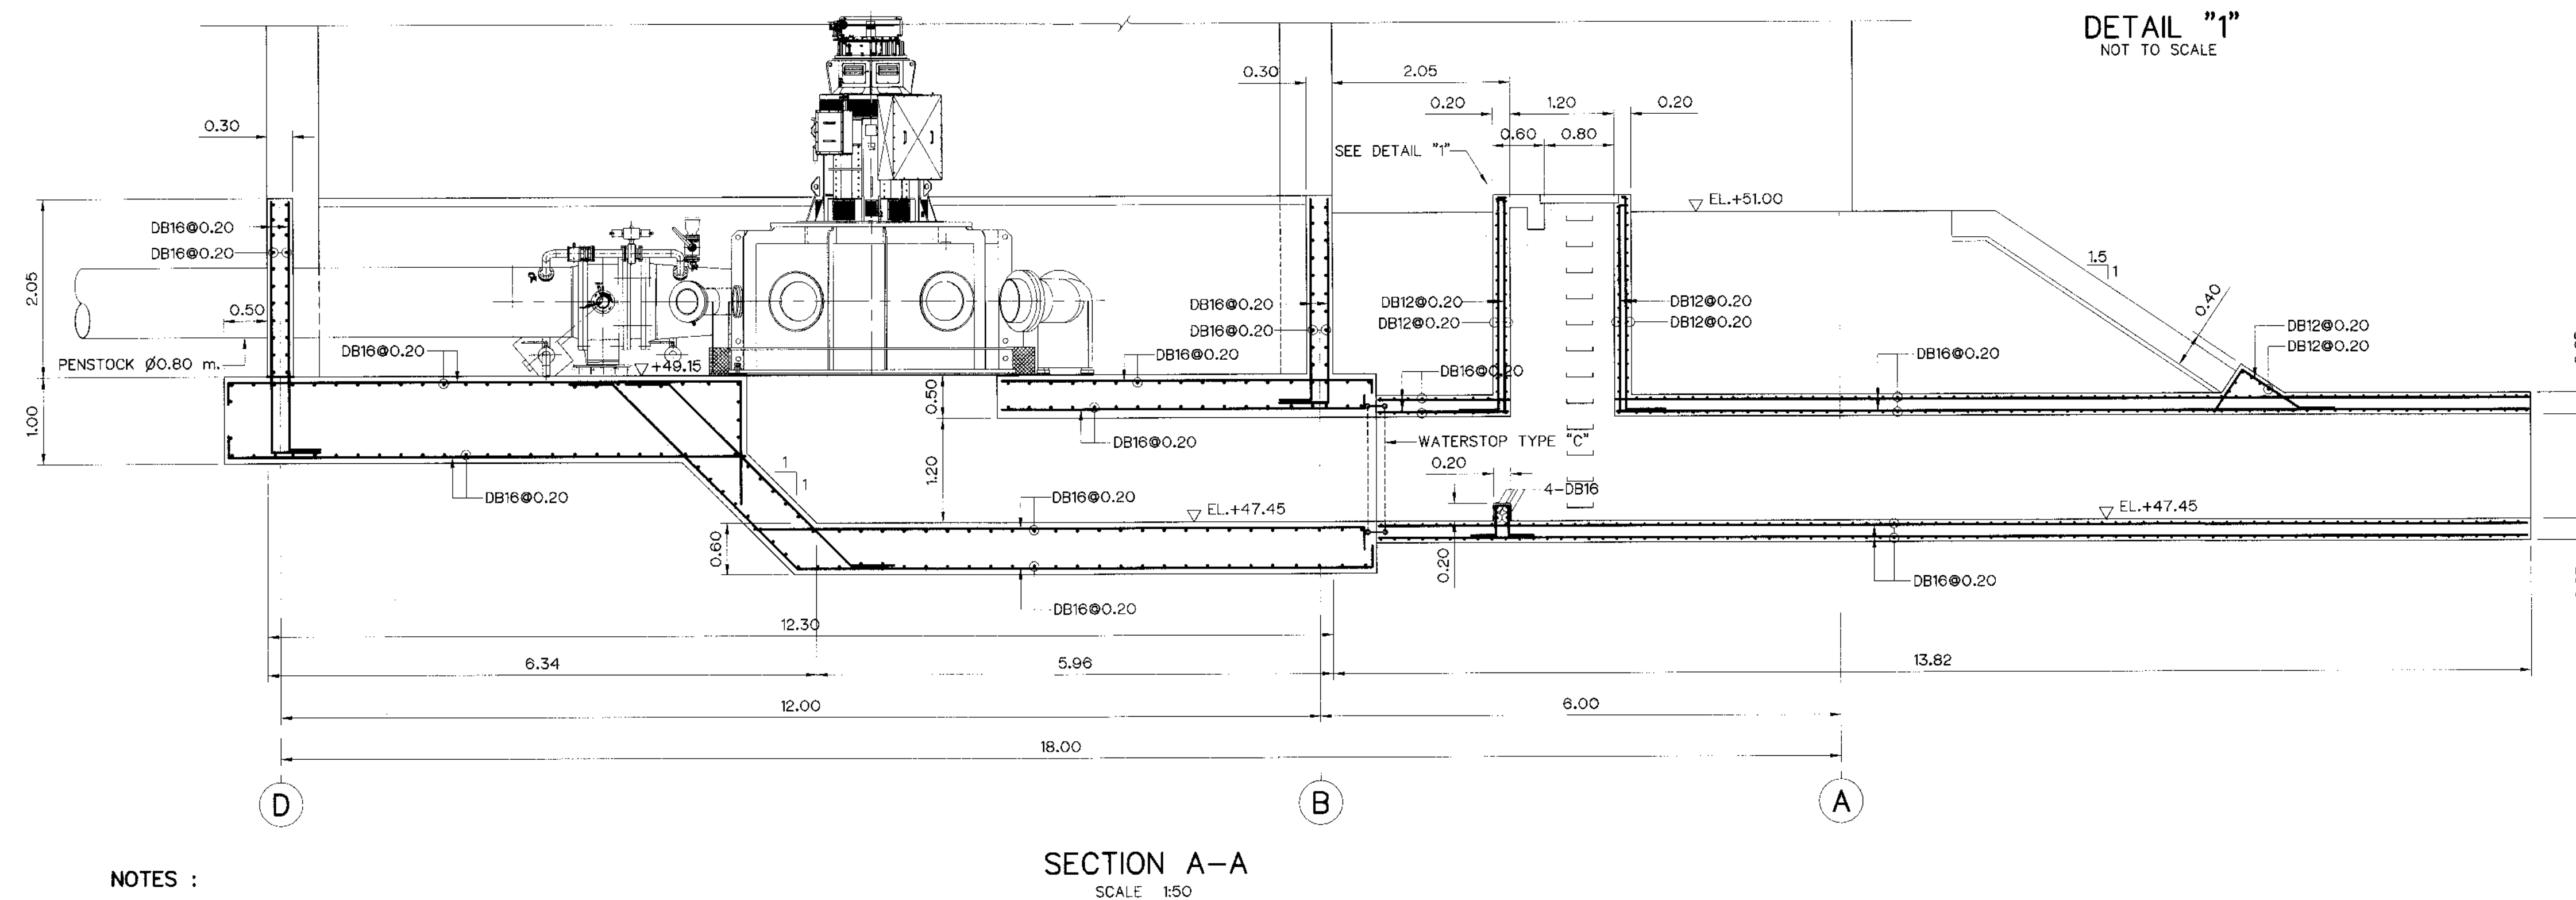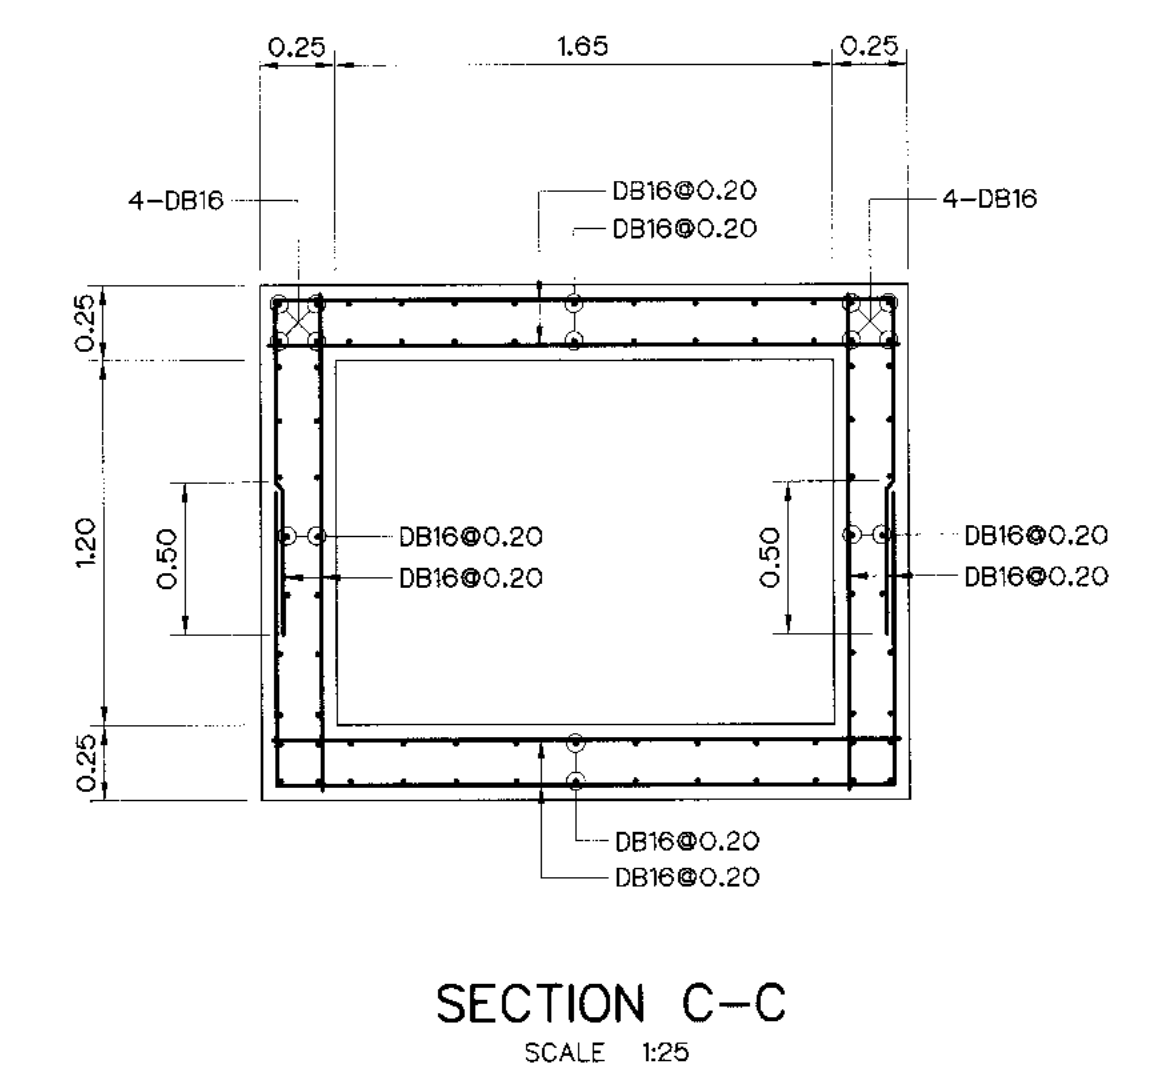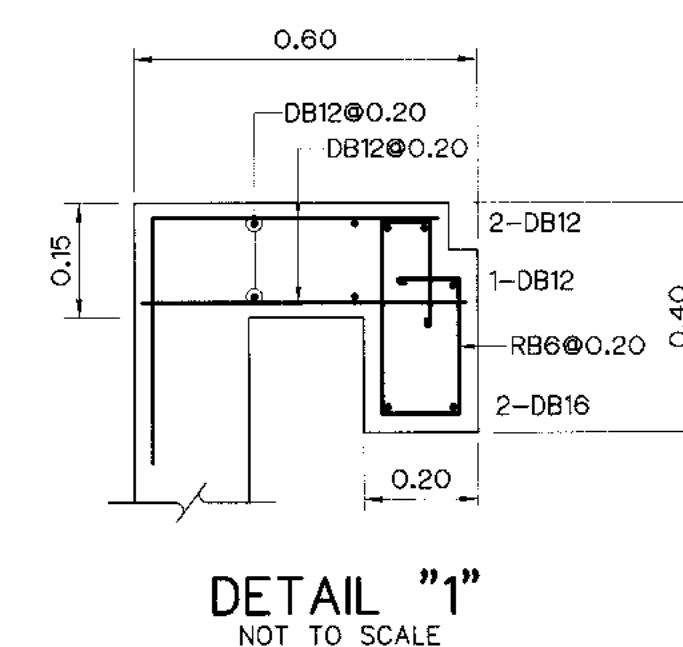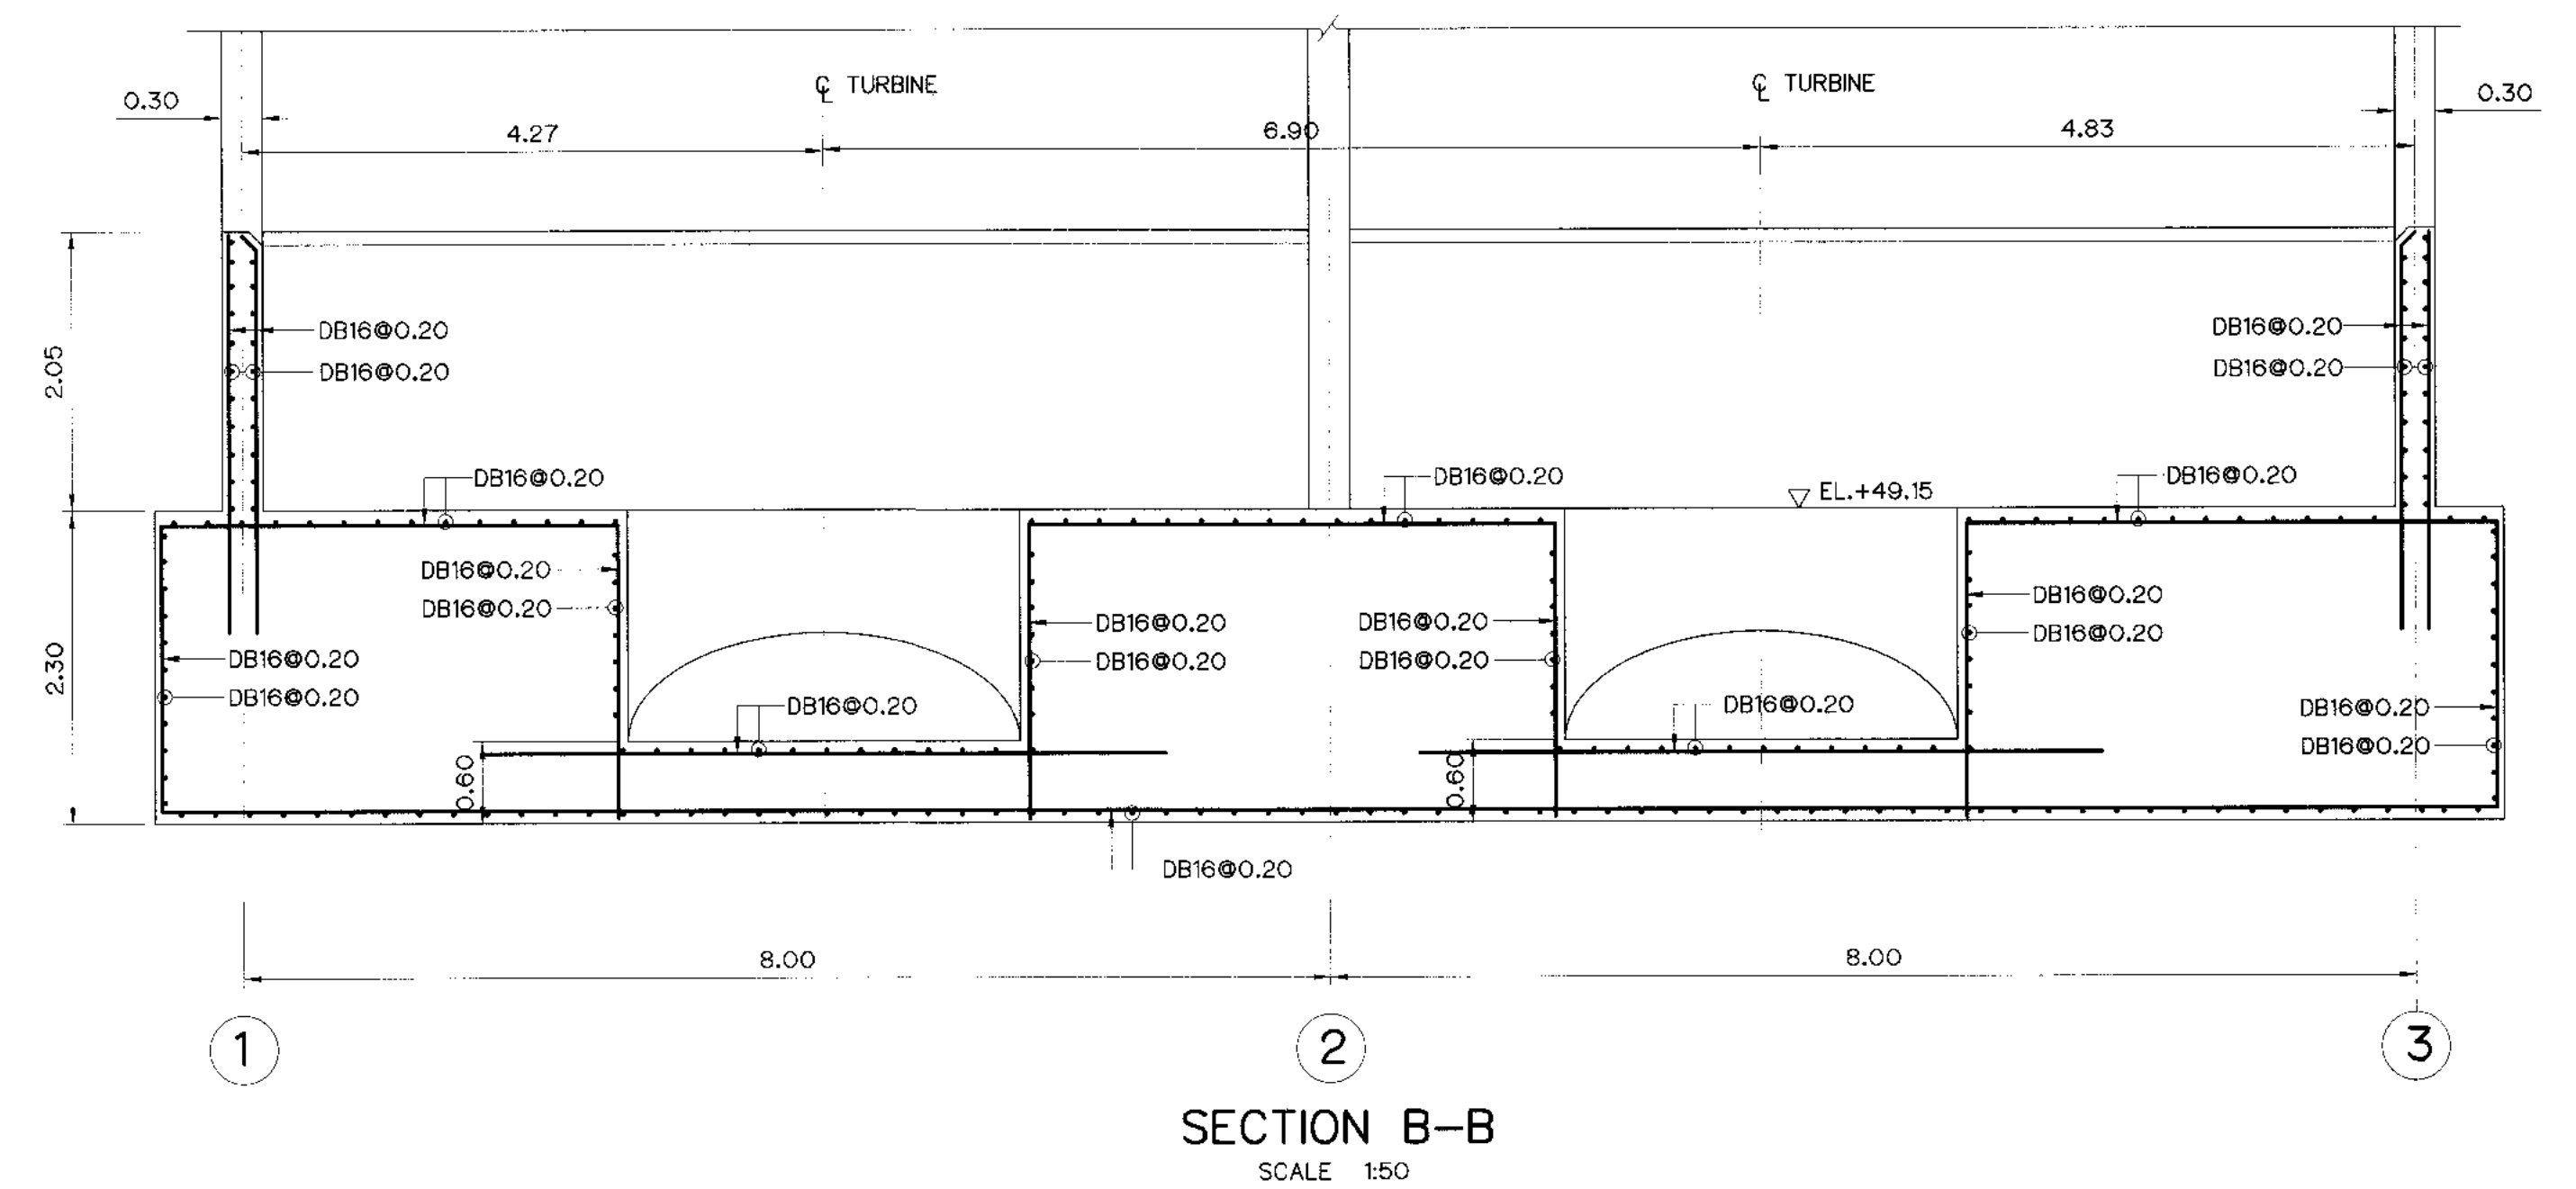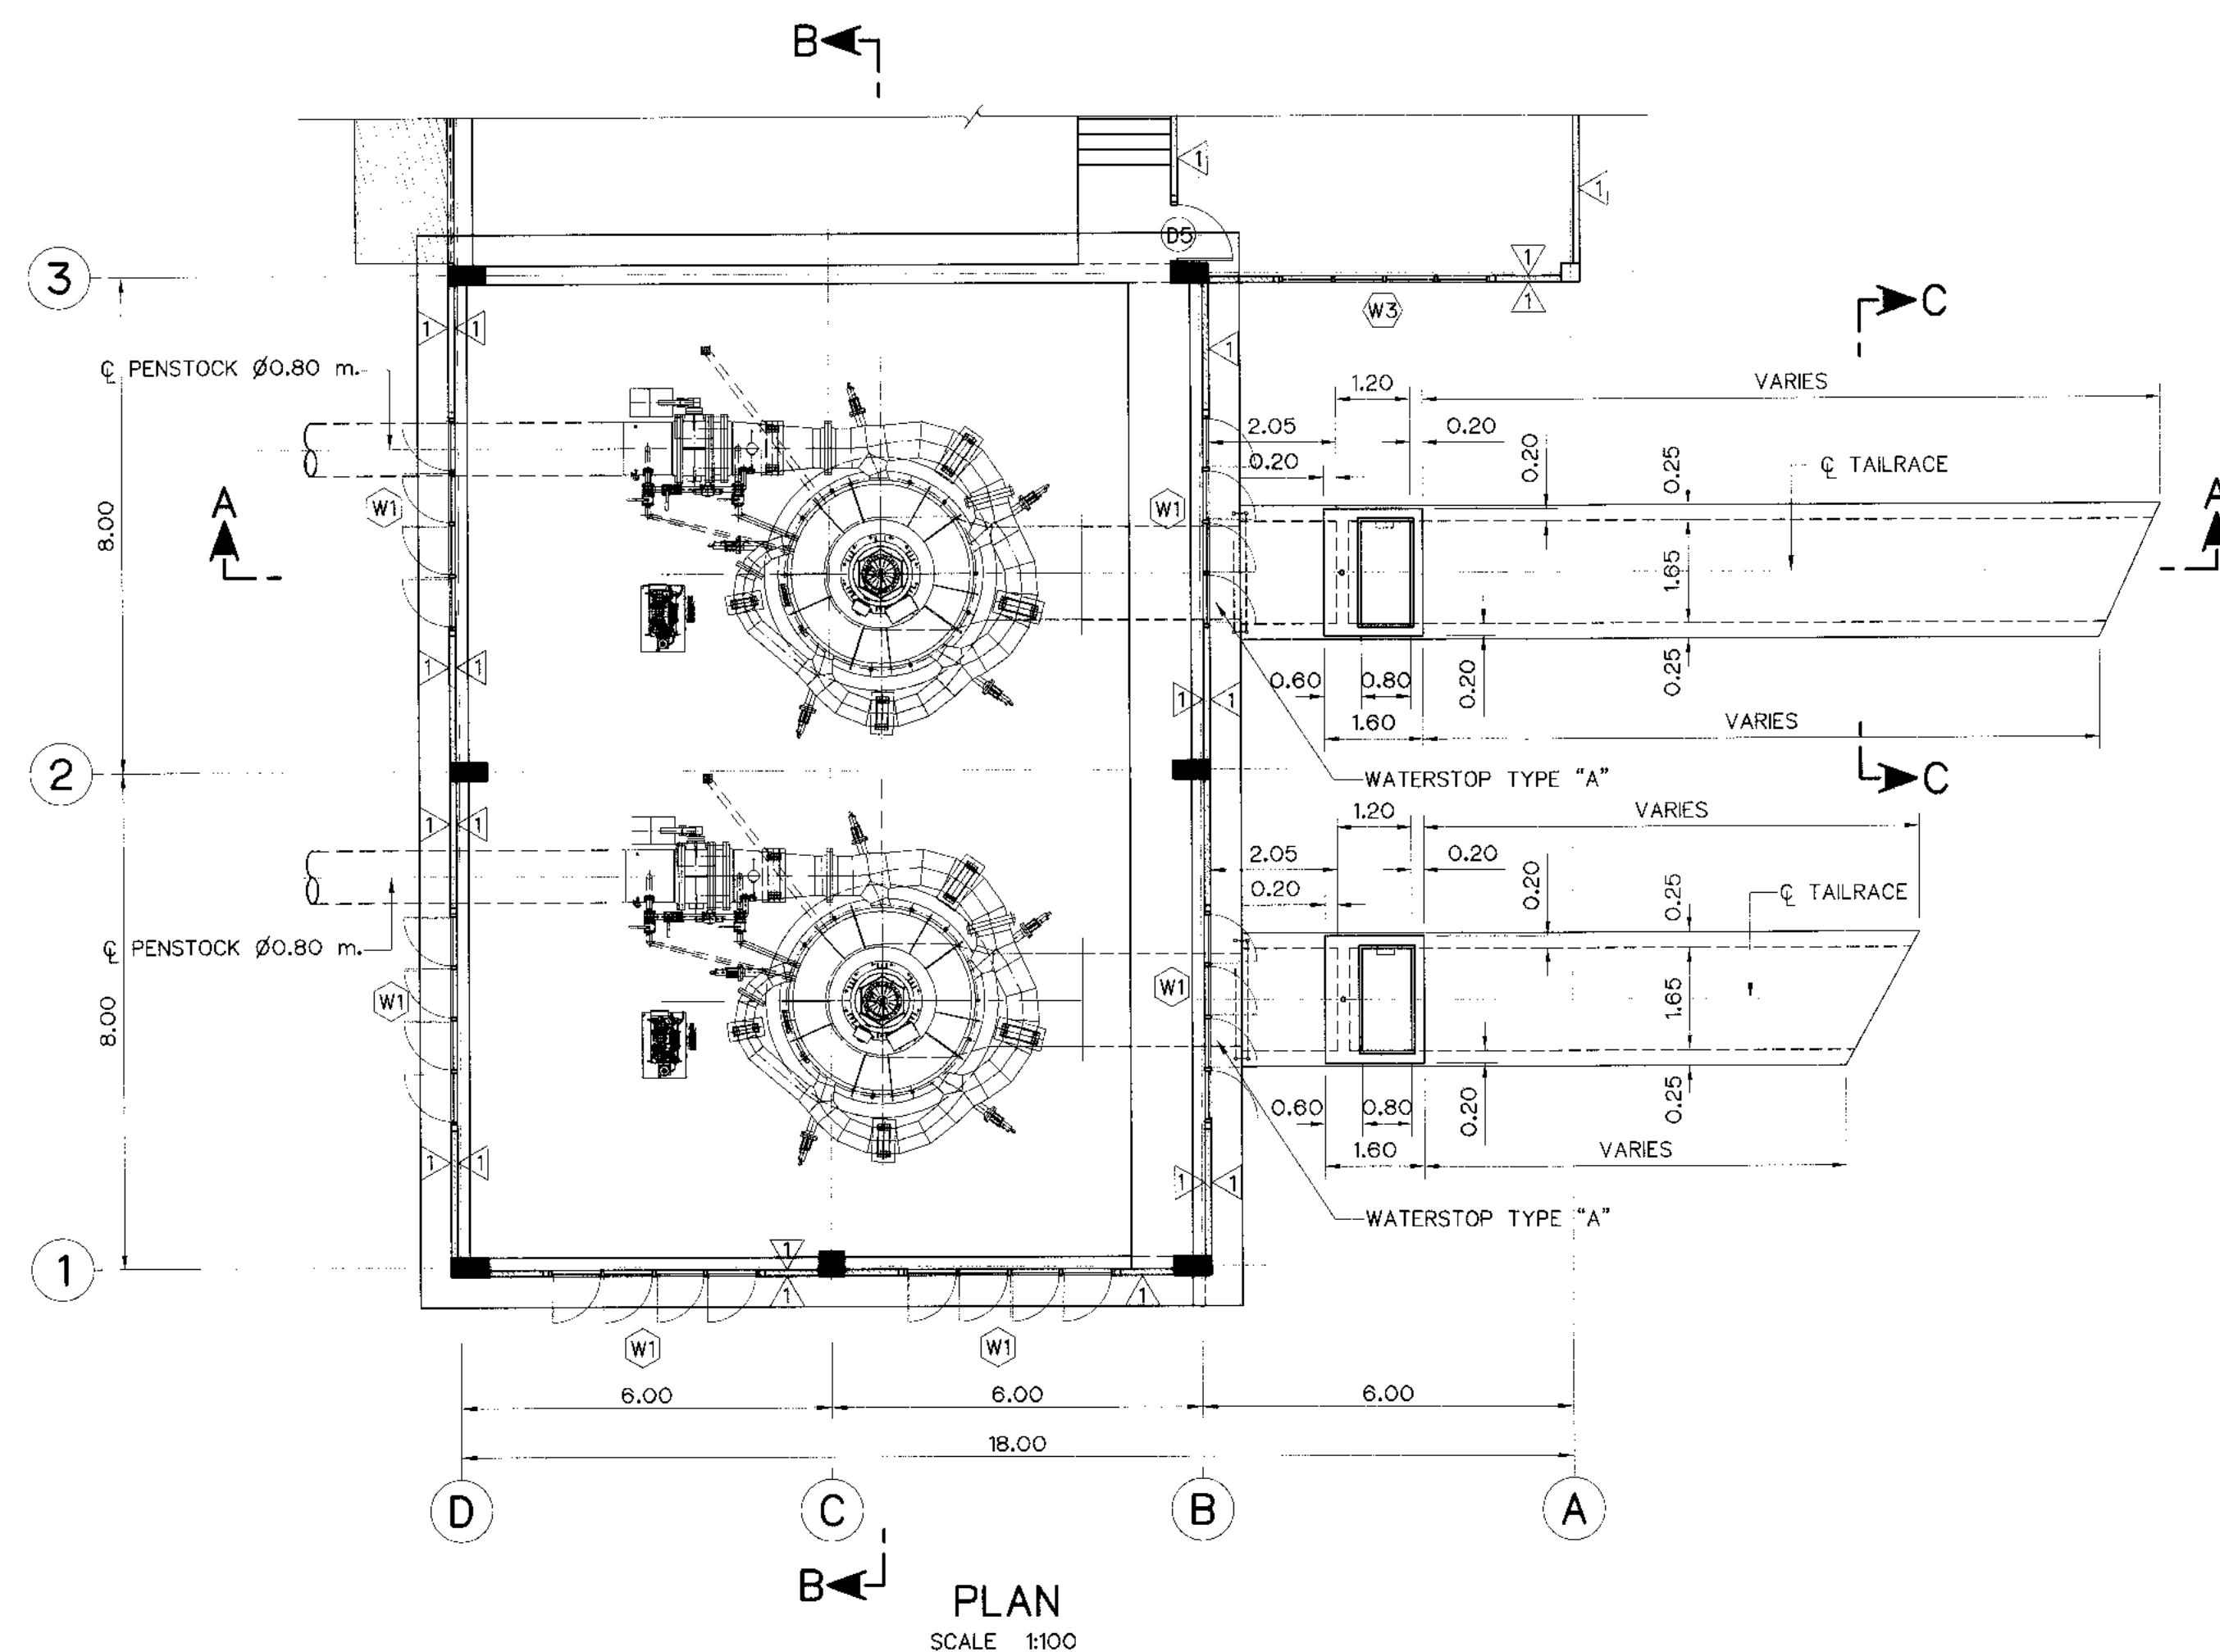


NOTES :

1. ALL DIMENSIONS AND ELEVATIONS (M.S.L.) ARE IN METERS,
UNLESS OTHERWISE SHOWN.
2. SYMBOLS, ABBREVIATIONS AND GENERAL NOTES SEE DWG. KLP-GN-03












REFERENCE DRAWINGS :

- | | |
|-----------------------------------|-----------|
| 1. TAILRACE, GENERAL LAY-OUT | KLP-TR-01 |
| 2. TAILRACE, SECTIONS AND DETAILS | KLP-TR-02 |

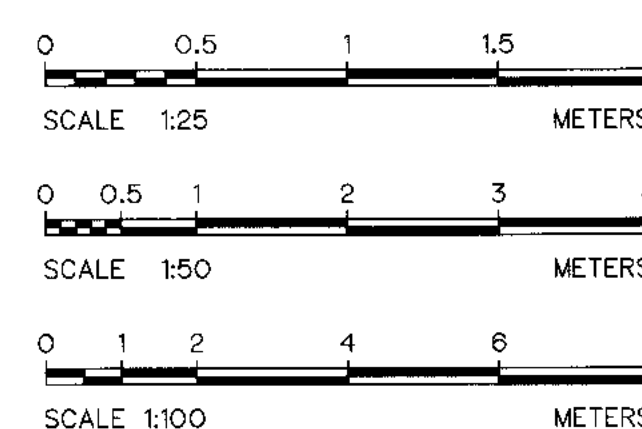


3				
2				
1				
NO.	DATE	REVISIONS	CHECKED	APPROVED
	CONSULTANTS		DEDE	

 KINGDOM OF THAILAND Department of Alternative Energy Development and Efficiency MINISTRY OF ENERGY	
KLONG LAM PLOK HYDROPOWER PROJECT	
CIVIL WORKS AND TRANSMISSION LINE TAILRACE REINFORCEMENT DETAILS	
 P&C MANAGEMENT CO.,LTD.	 Department of Alternative Energy Development and Efficiency MINISTRY OF ENERGY
DESIGNED <i>h</i> 28/29074 <i>h</i> 28.6226	REVIEWED <i>h</i>
DRAWN <i>h</i>	SUBMITTED <i>h</i>
CHECKED <i>h</i> 28.6226	APPROVED <i>P. Heng</i>
PROJECT MANAGER <i>h</i>	SHEET NO. 99 OF 110

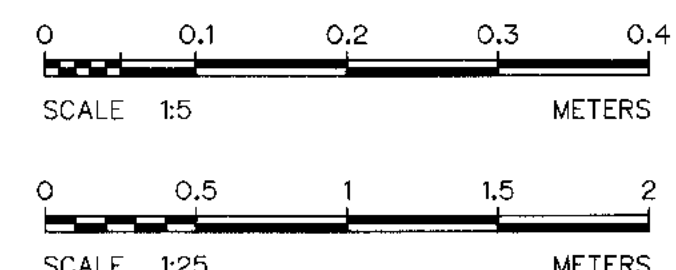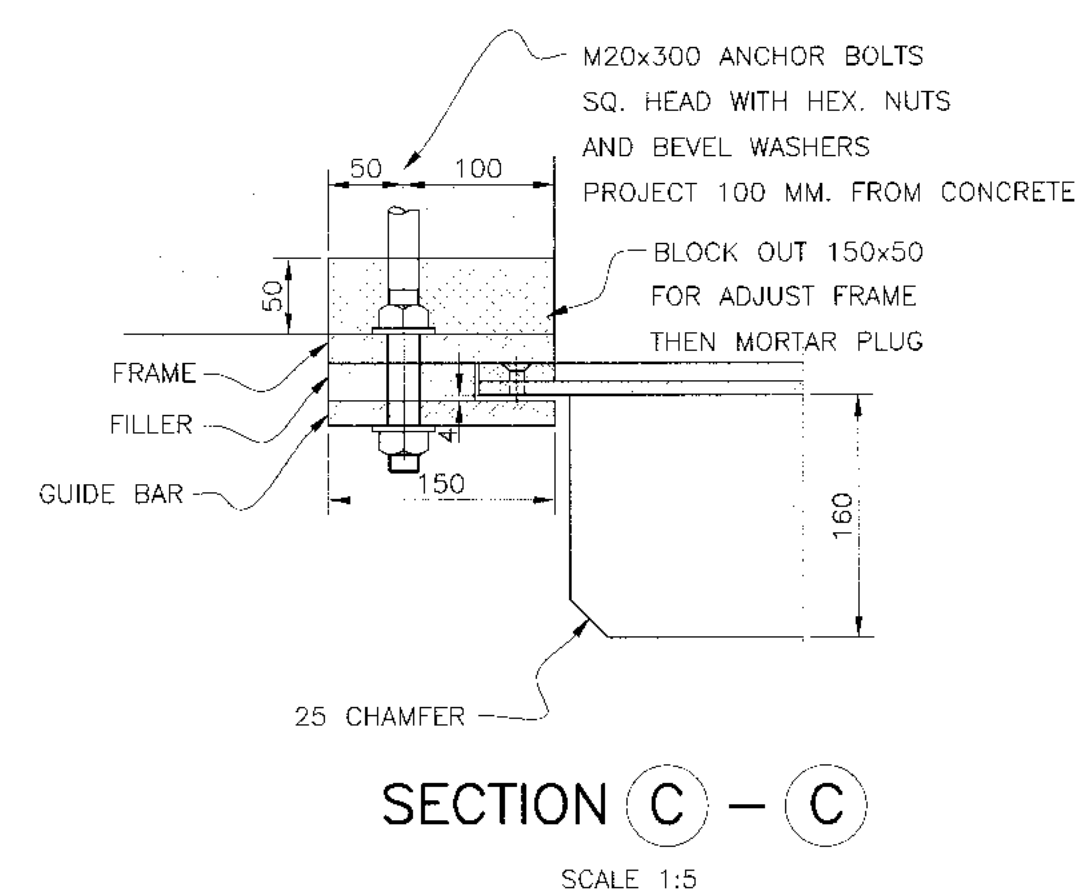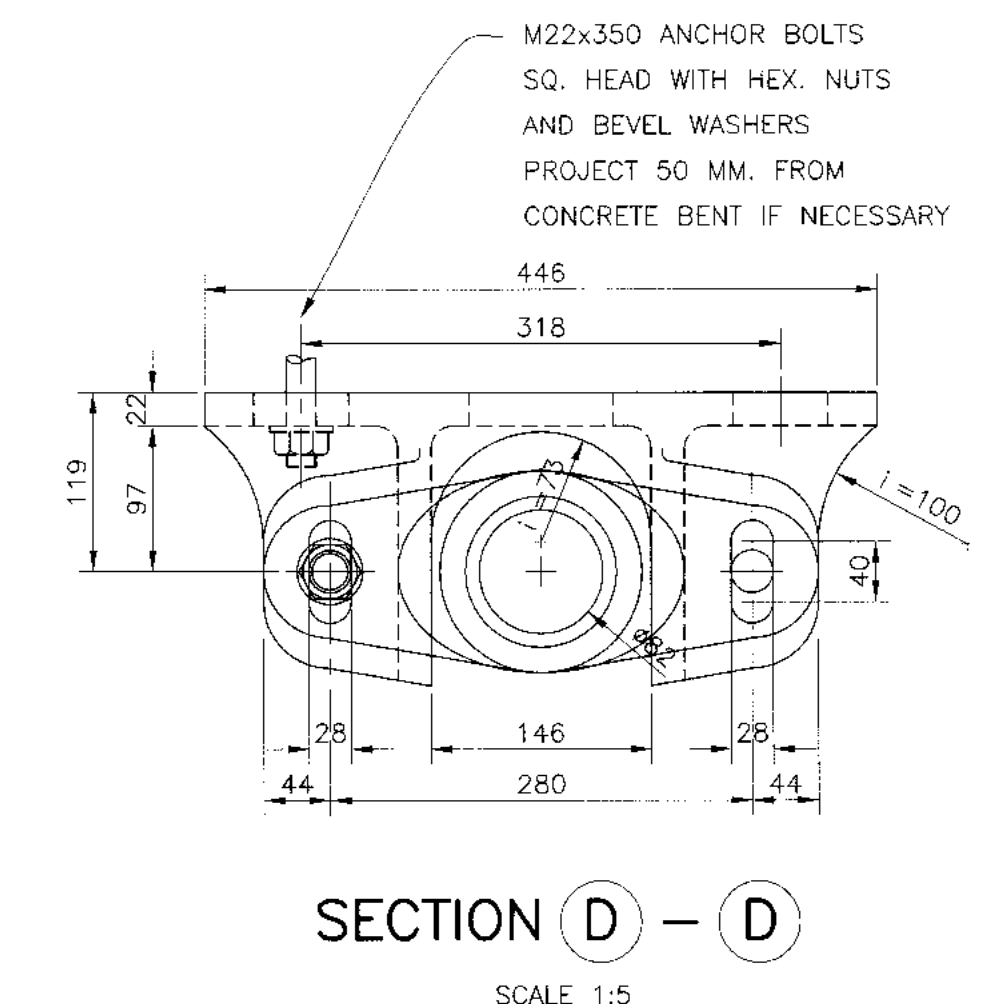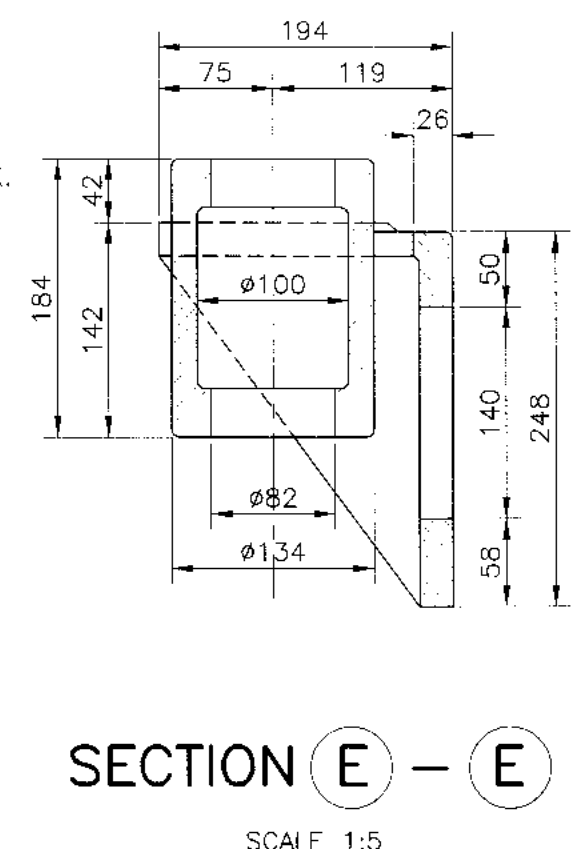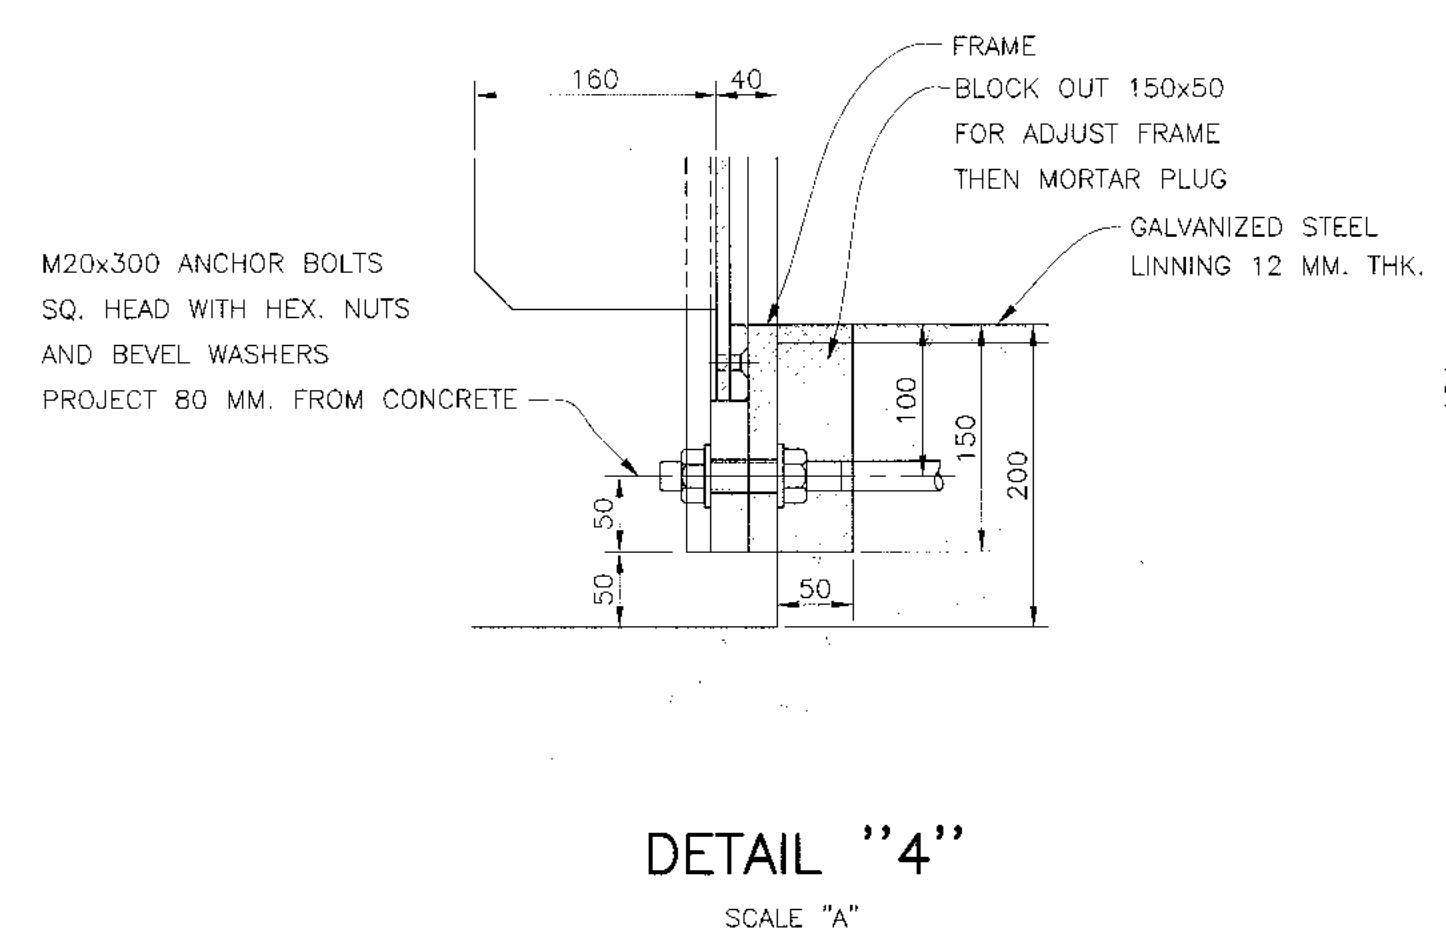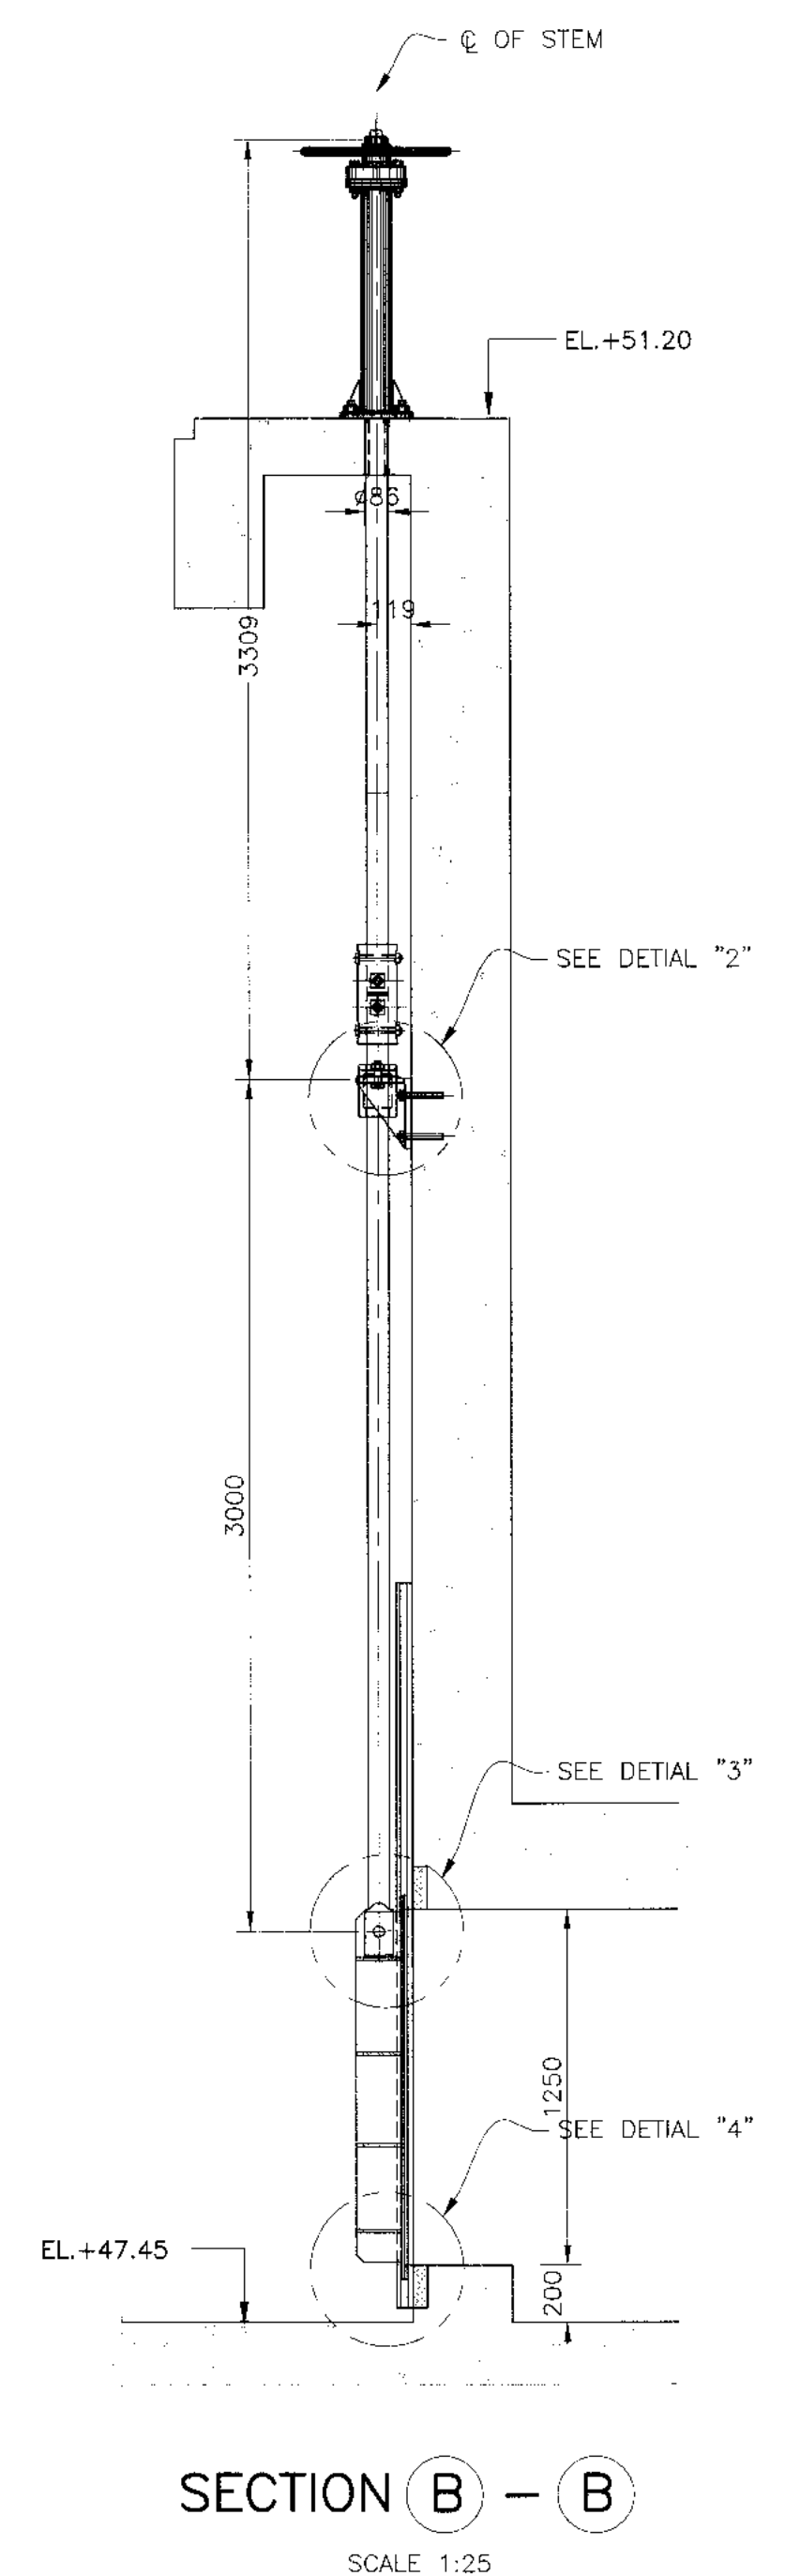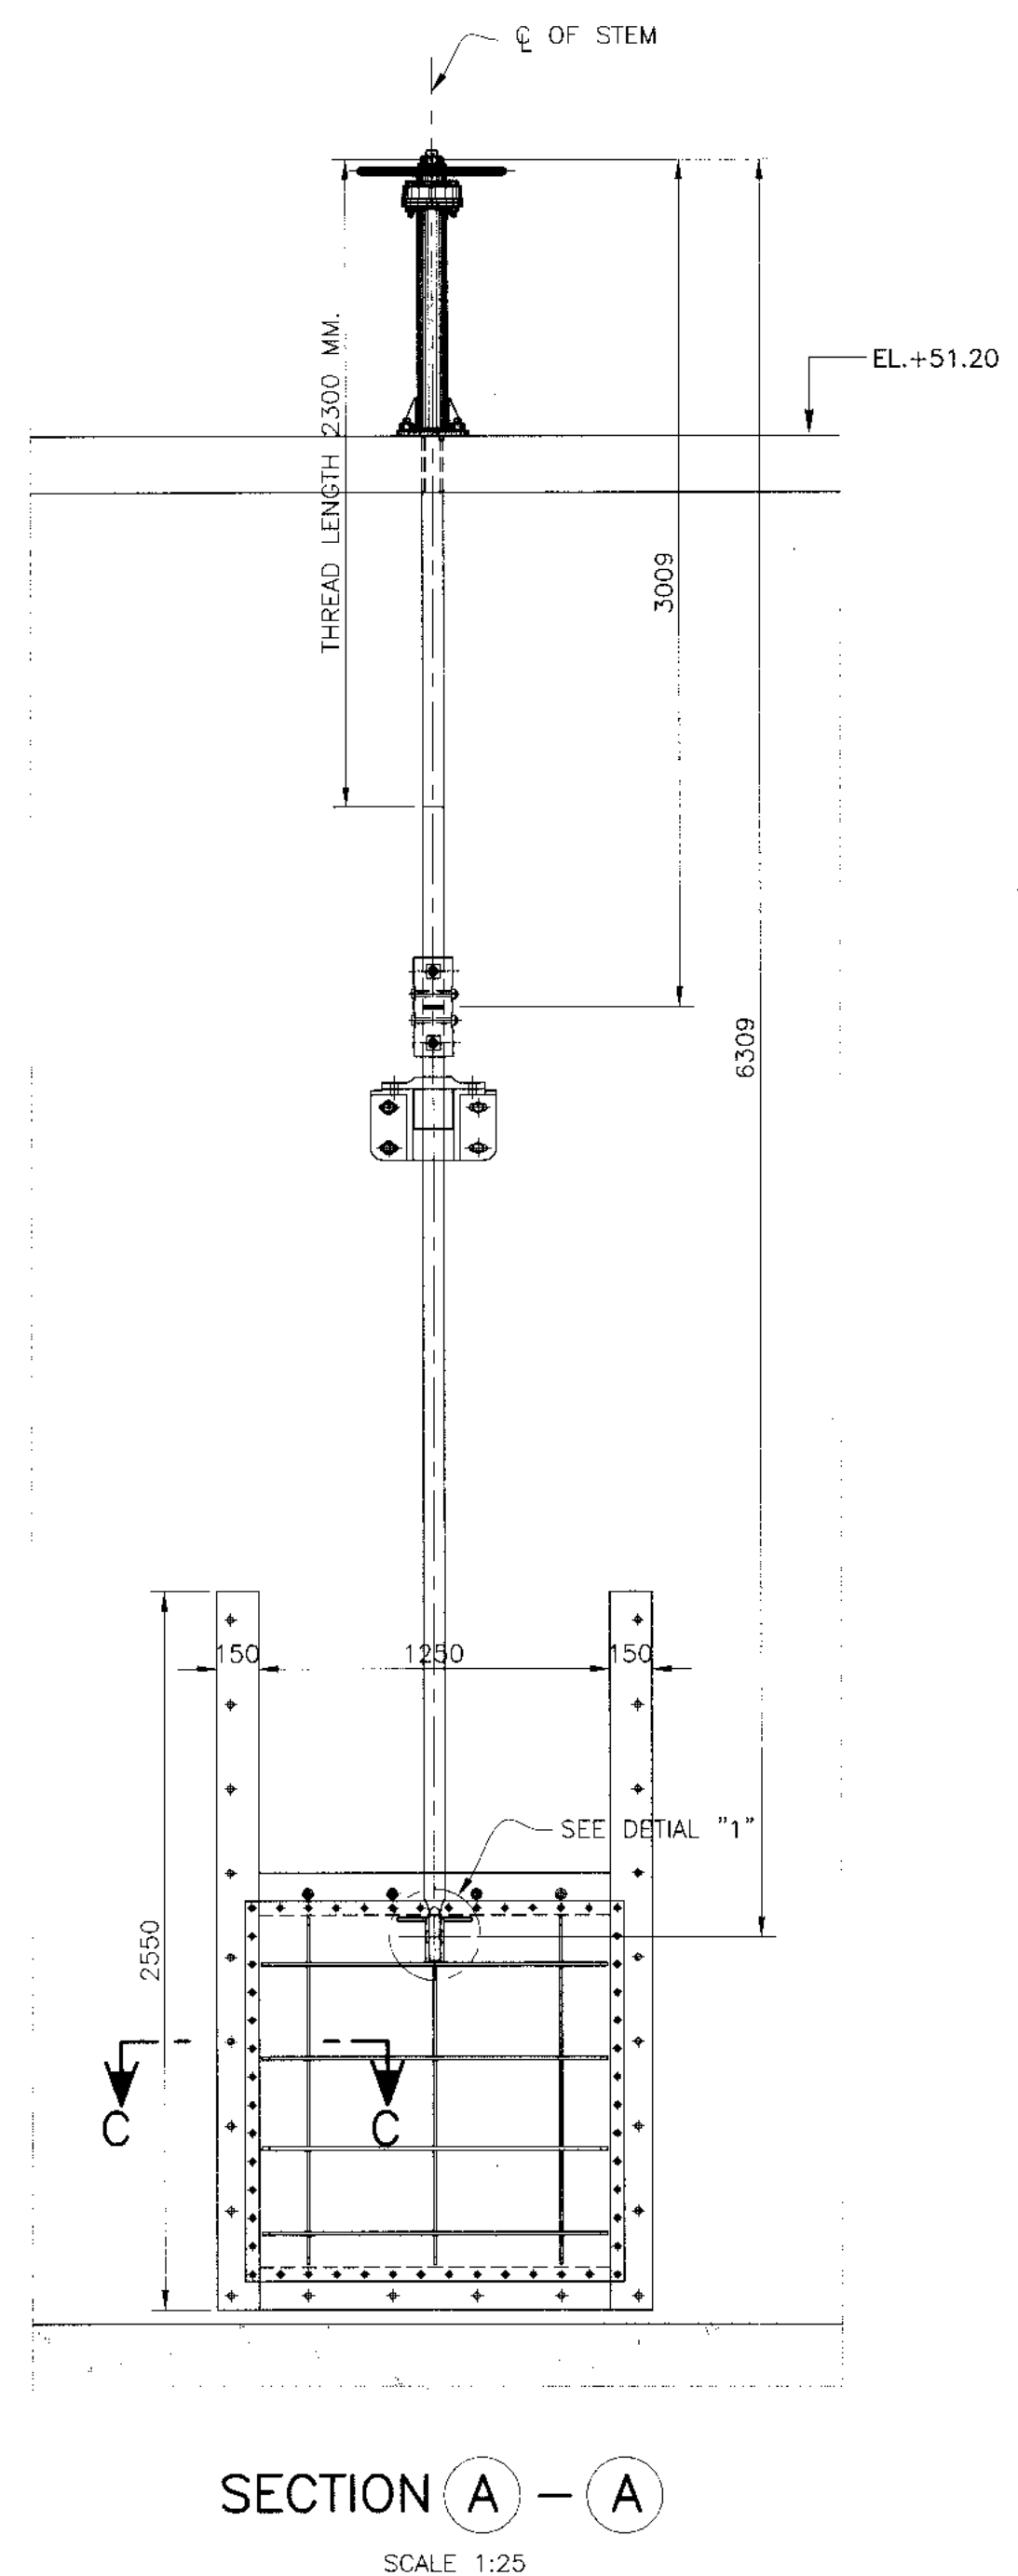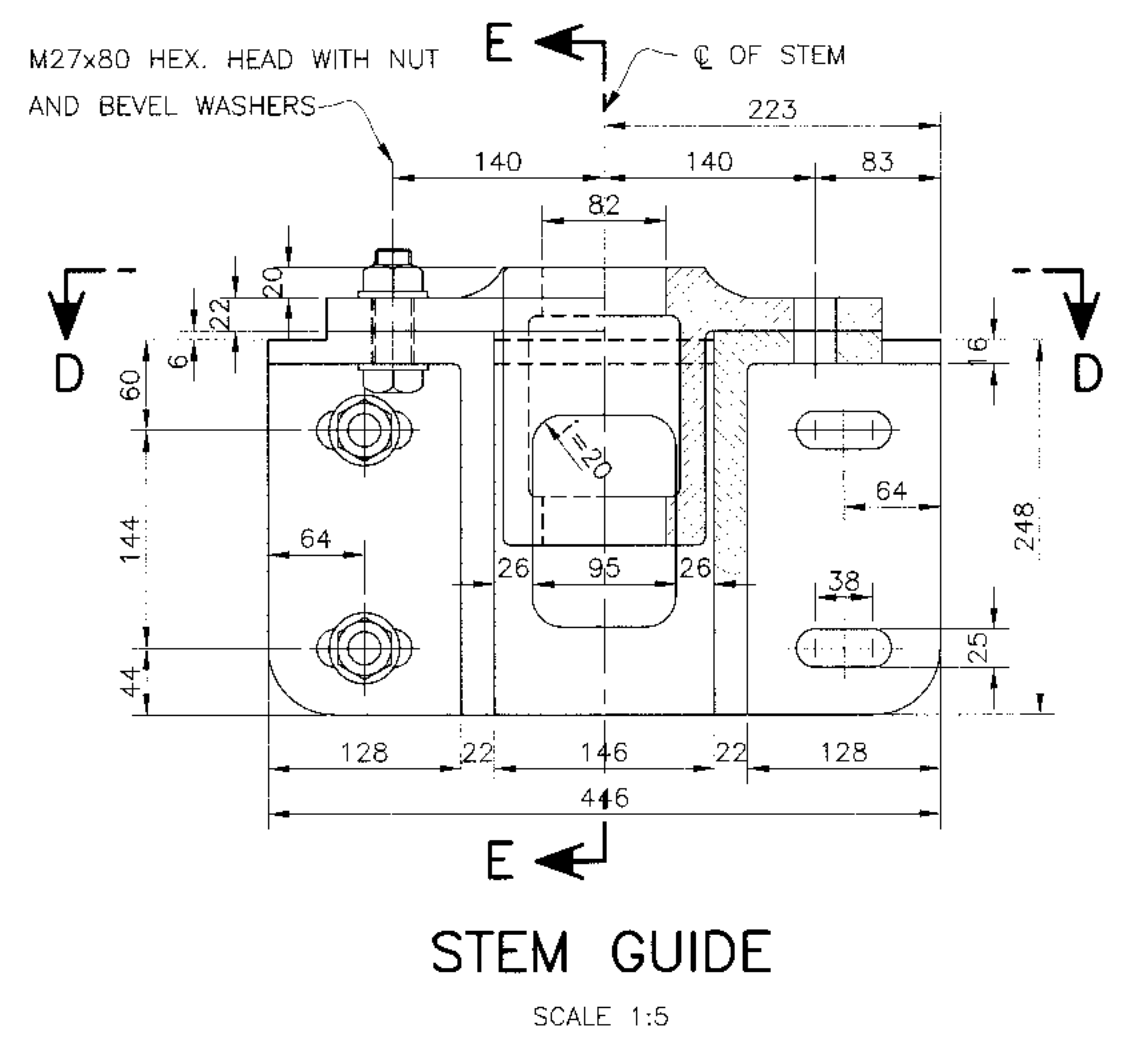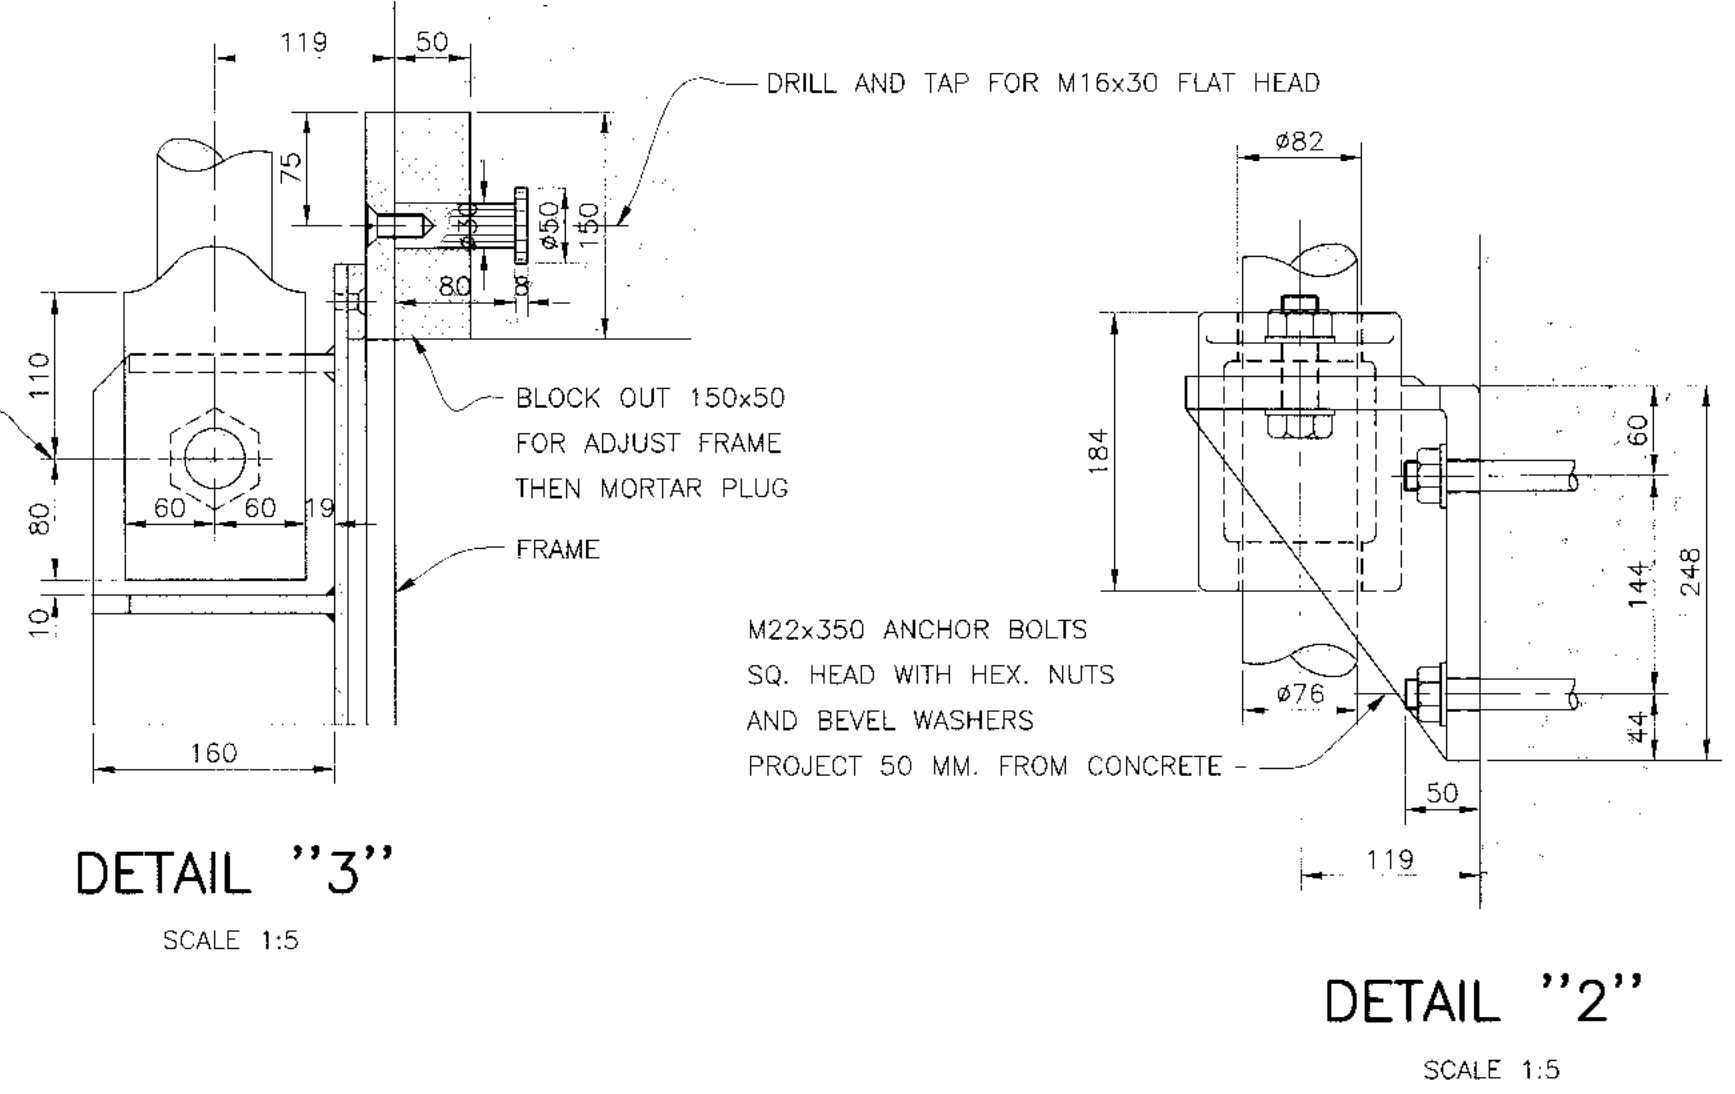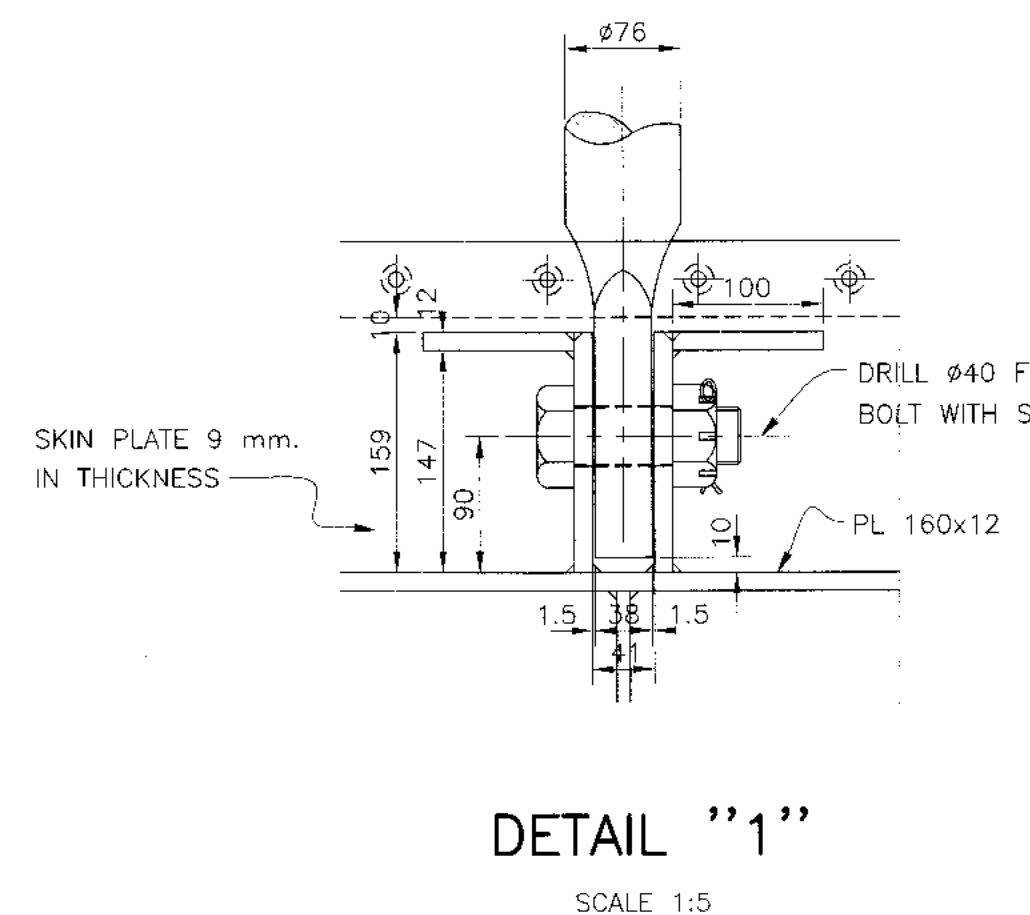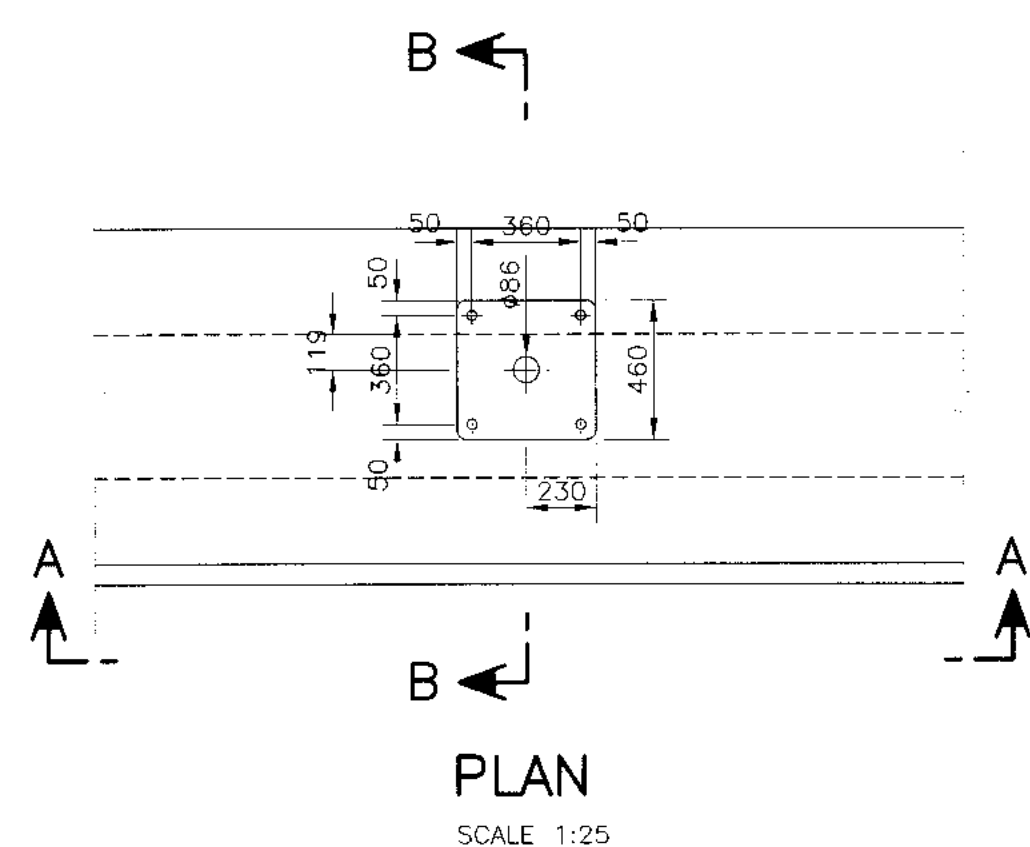


- NOTE :**
- ALL DIMENSIONS ARE IN MILLIMETERS, UNLESS OTHERWISE SHOWN.
 - ALL WELDING WILL BE 6 MILLIMETERS, UNLESS OTHERWISE SHOWN.
 - ALL BOLTS AND NUTS USE ASTM A325
 - ALL STRUCTURAL STEELS ARE JIS G 3101 SS400
 - ALL STAINLESS STEELS PLATES ARE JIS G 4304 SUS 304
- REFERENCE DWGS :**
- | | |
|--|-----------|
| 1. TAILRACE SECTION AND DETAILS | KLP-TR-02 |
| 2. TAILRACE 1.25x1.25 m. VERTICAL GATE GATE DETAIL | KLP-TR-05 |
| 3. WEIR INTAKE STRUCTURE GATE-LIFT PEDESTALS | KLP-WE-13 |
| 4. WEIR VERTICAL SCREW-LIFT CAPACITY 2,250 KG. | KLP-WE-14 |


KINGDOM OF THAILAND Department of Alternative Energy Development and Efficiency MINISTRY OF ENERGY			
KLONG LAM PLOK HYDROPOWER PROJECT			
CIVIL WORKS AND TRANSMISSION LINE			
TAILRACE			
1.25x1.25 m. VERTICAL GATE GATE INSTALLATION			
DESIGNED <i>[Signature]</i> 08/29/07 08/29/07	REVIEWED <i>[Signature]</i>	PROJECT MANAGER <i>[Signature]</i> 08/03/2559 DATE	
DRAWN <i>[Signature]</i>	RECOMMENDED <i>[Signature]</i>	DRIVING NO. KLP-TR-04	
CHECKED <i>[Signature]</i> 08/29/07	APPROVED <i>[Signature]</i>	SHEET NO. 100 OF 110	

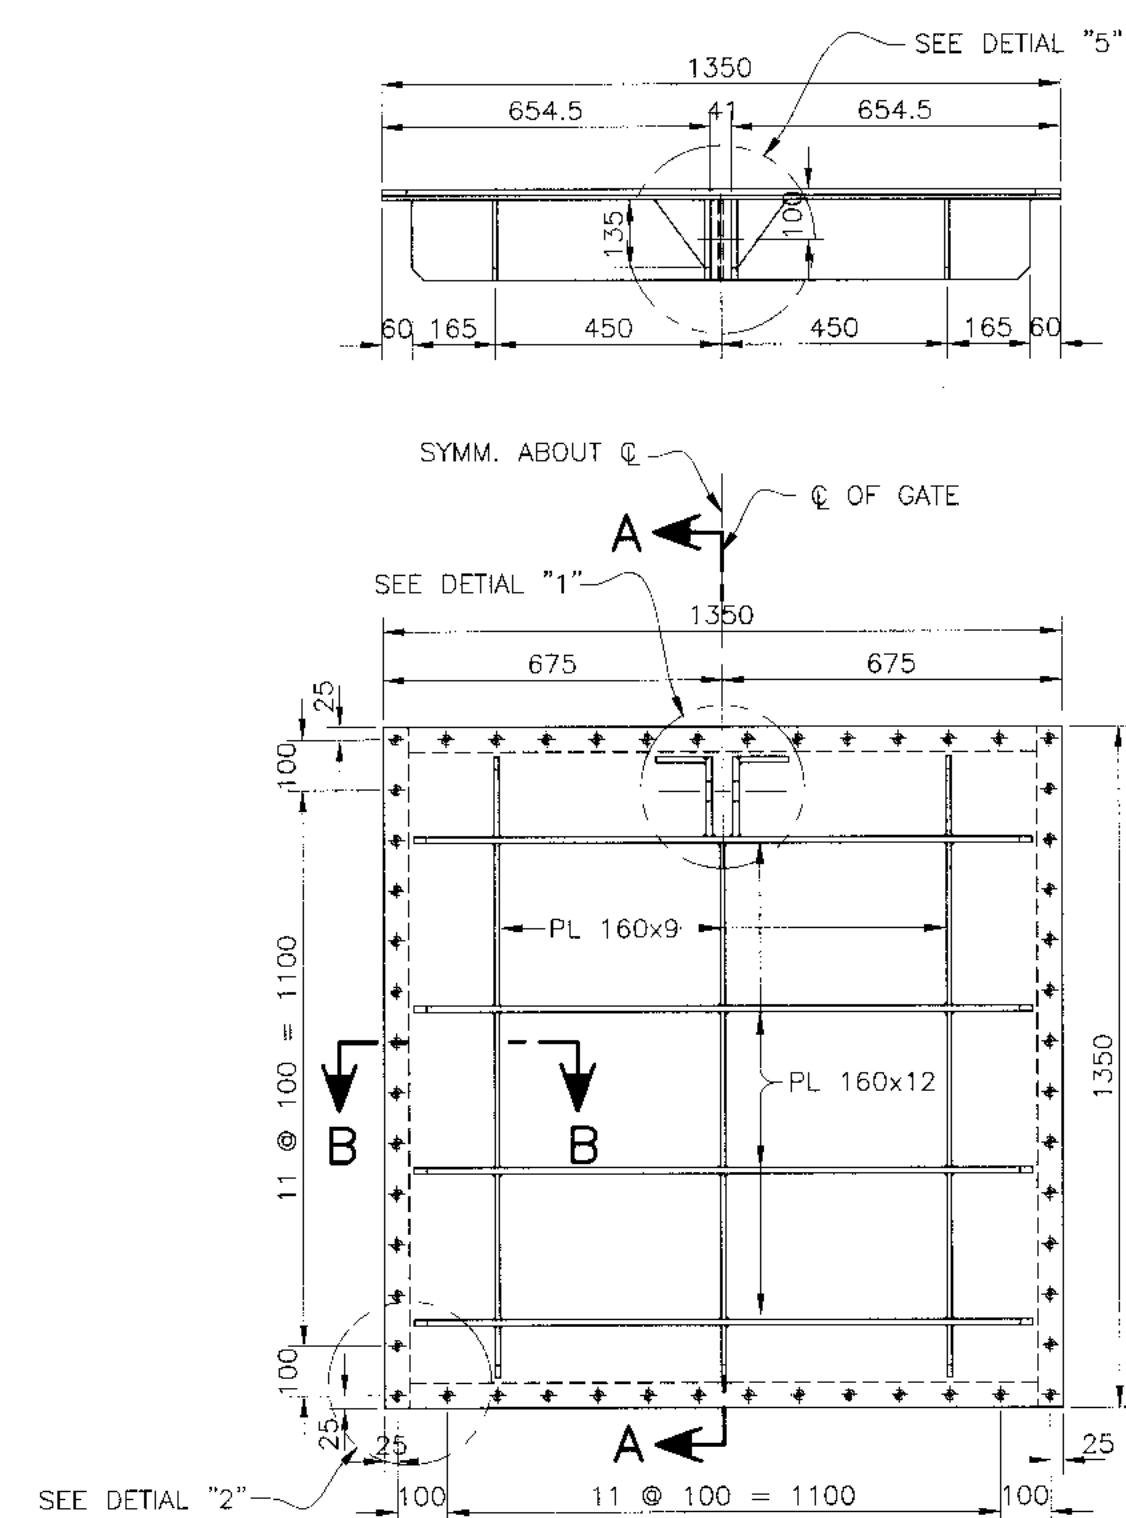


GATE LEAF
SCALE 1:15

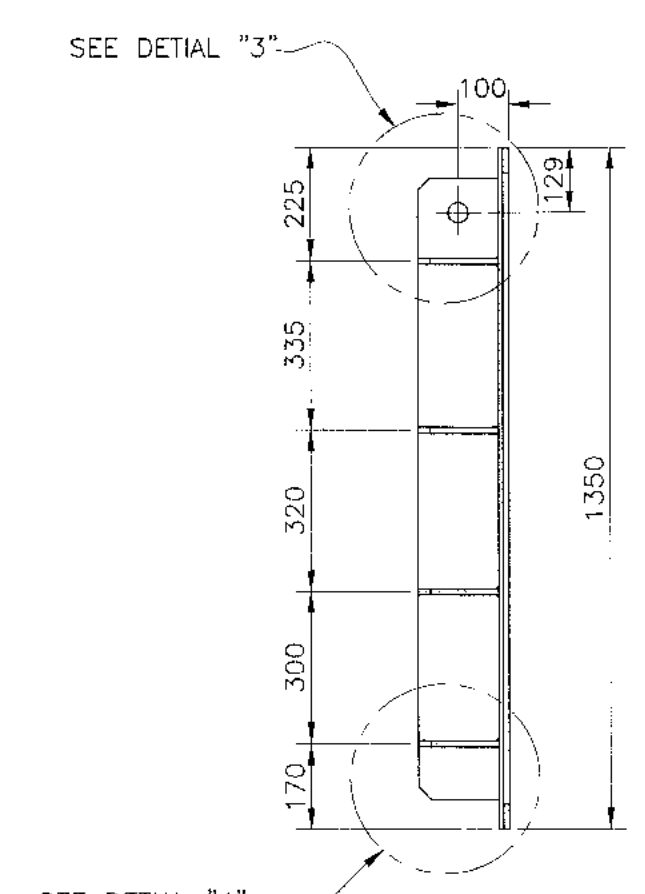


SECTION A - A
SCALE 1:15

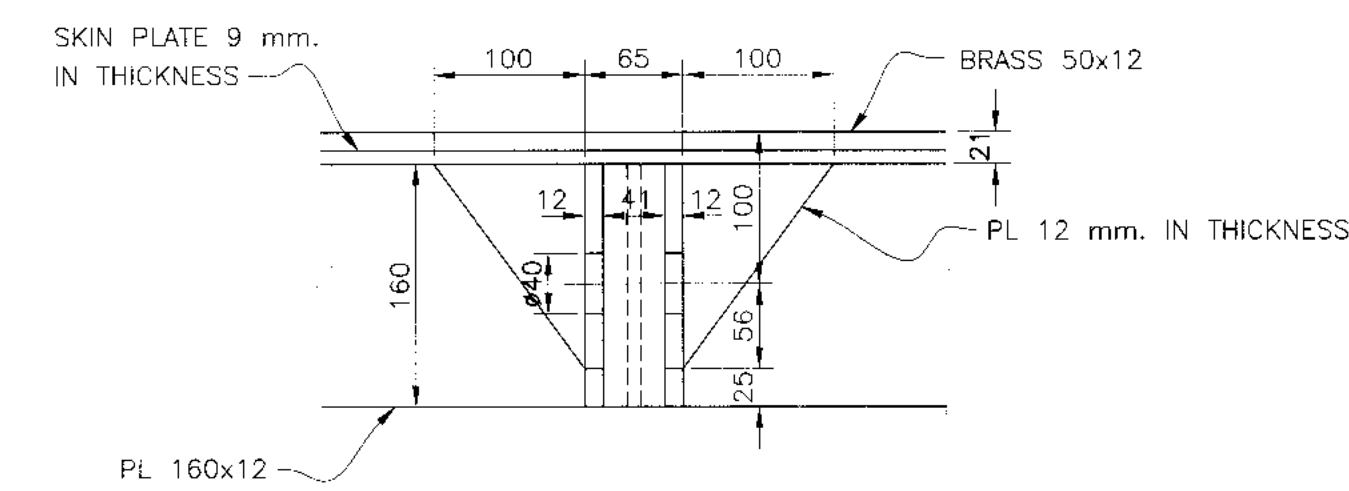


DETAIL "5"
SCALE 1:5

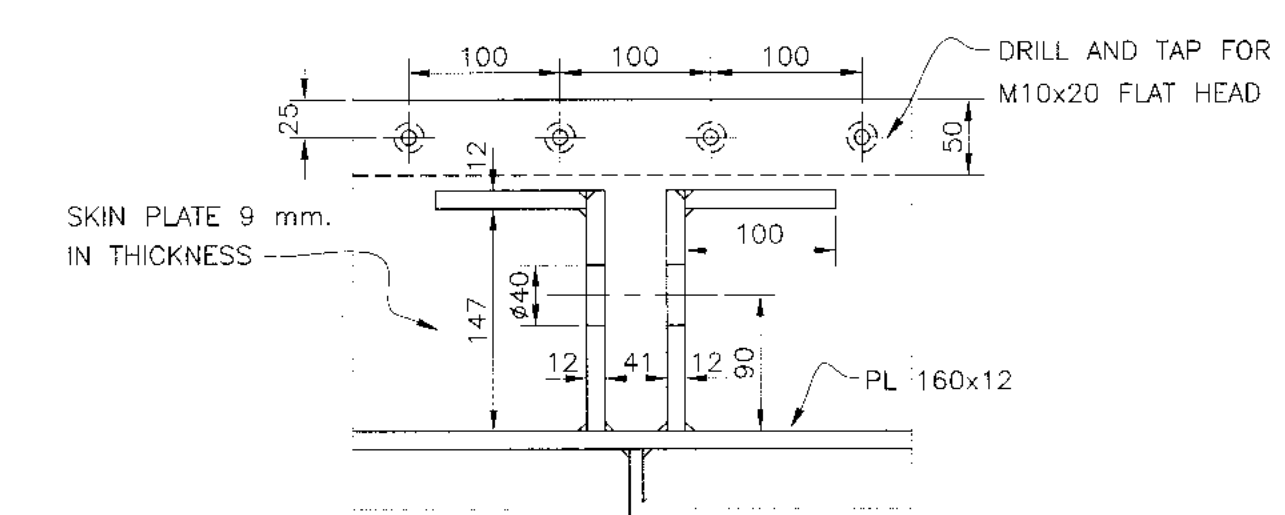


DETAIL "1"
SCALE 1:5

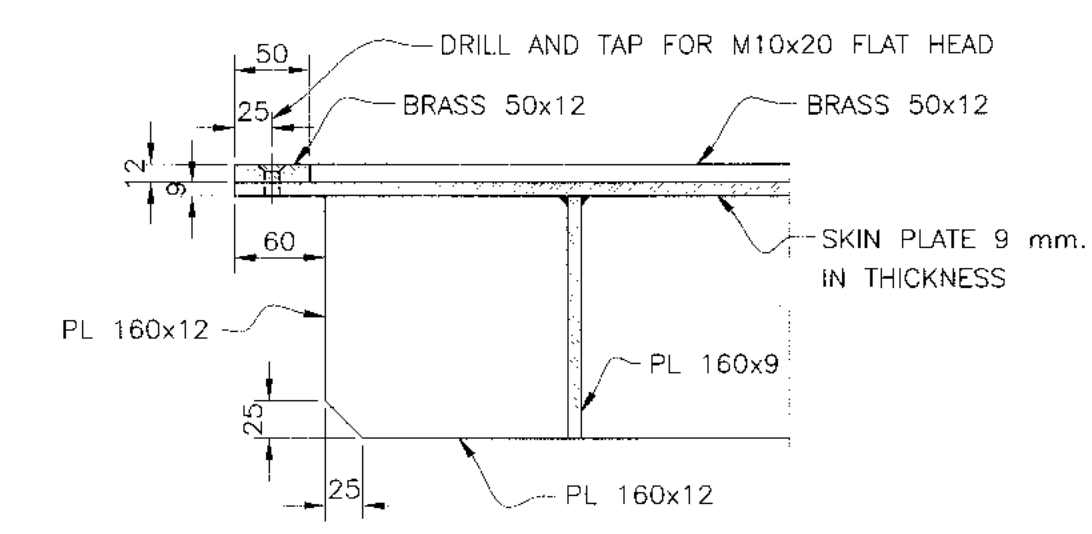


SECTION B - B
SCALE 1:5

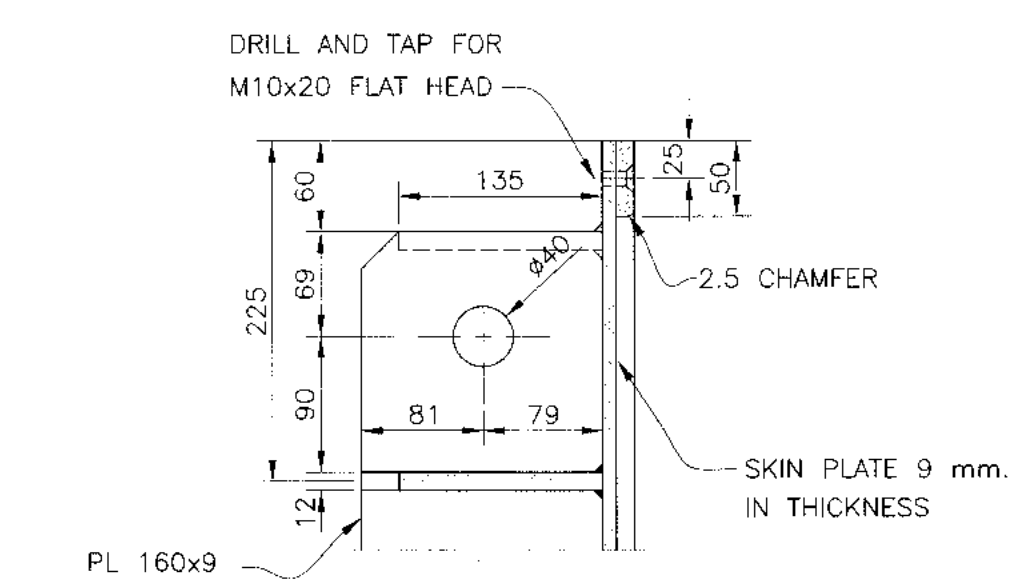


DETAIL "3"
SCALE 1:5

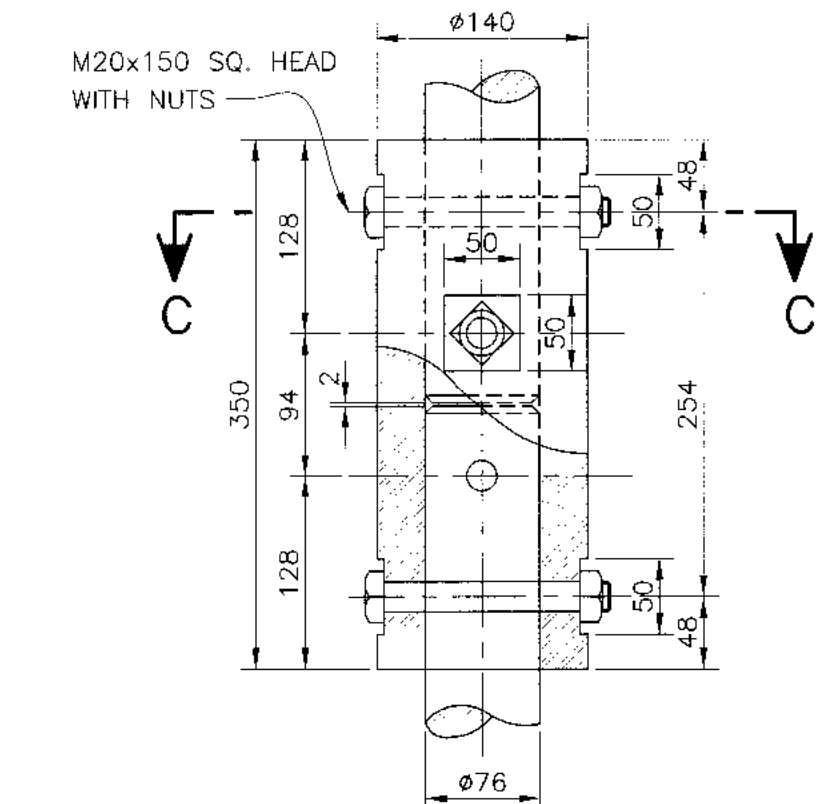

COUPLING
SCALE 1:5

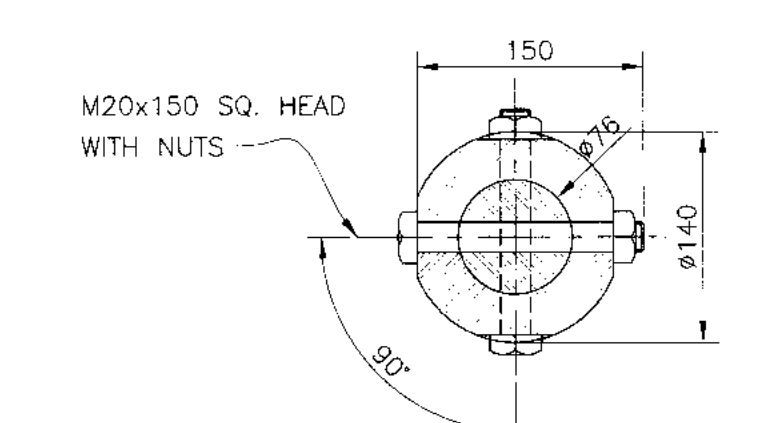


SECTION C - C
SCALE 1:5


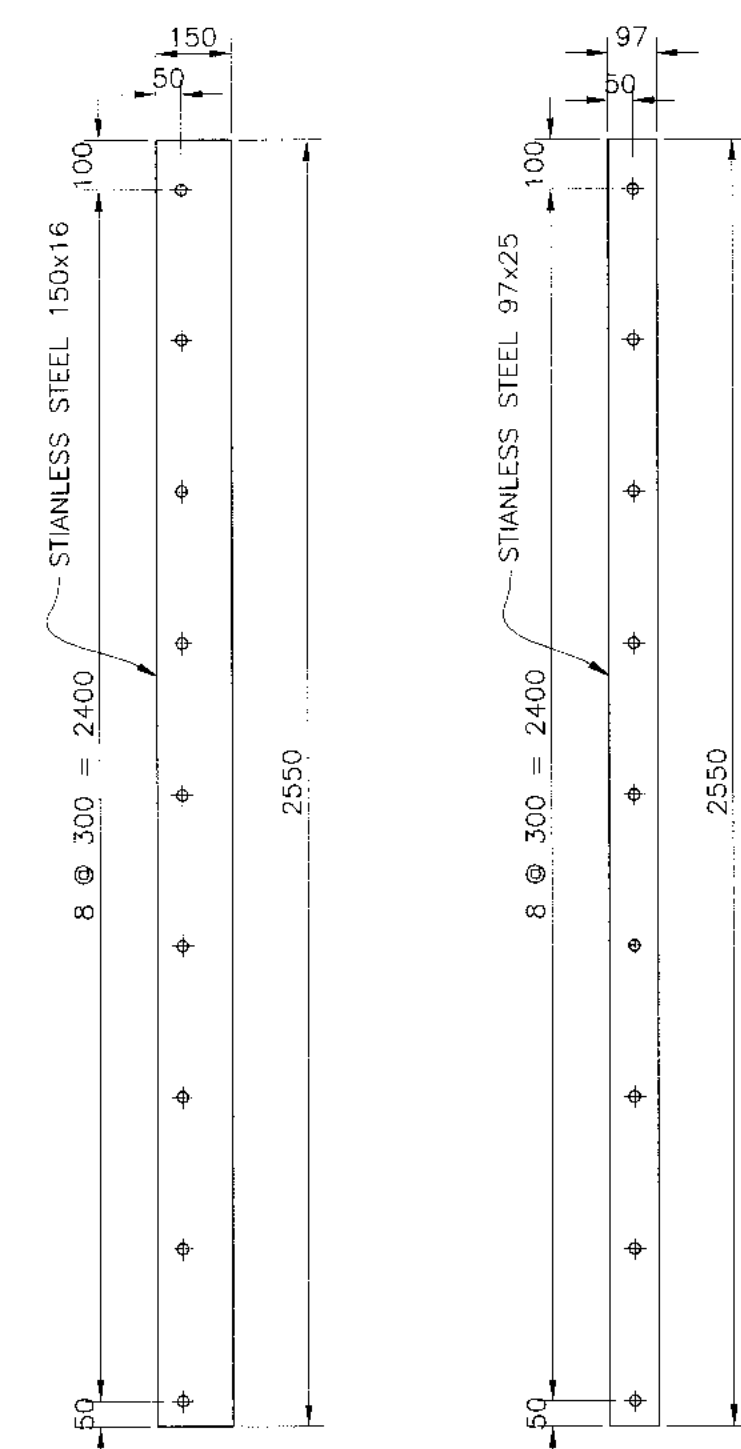


GUIDE BAR
SCALE "B"

FILLER
SCALE 1:15

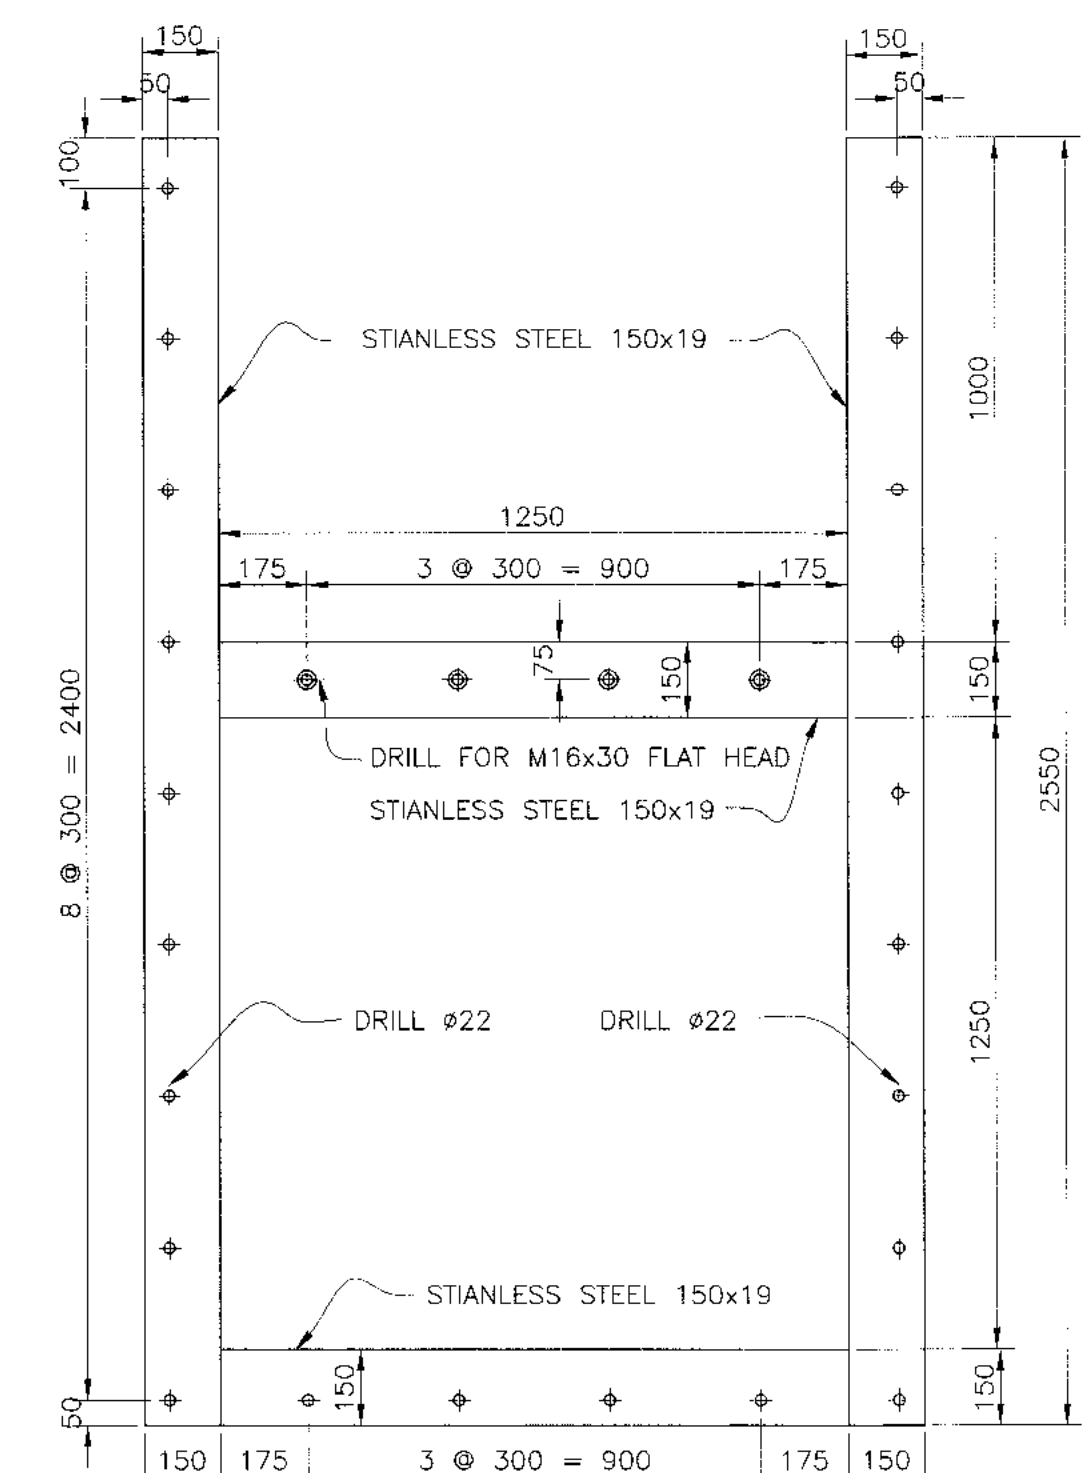

FRAME
SCALE 1:15

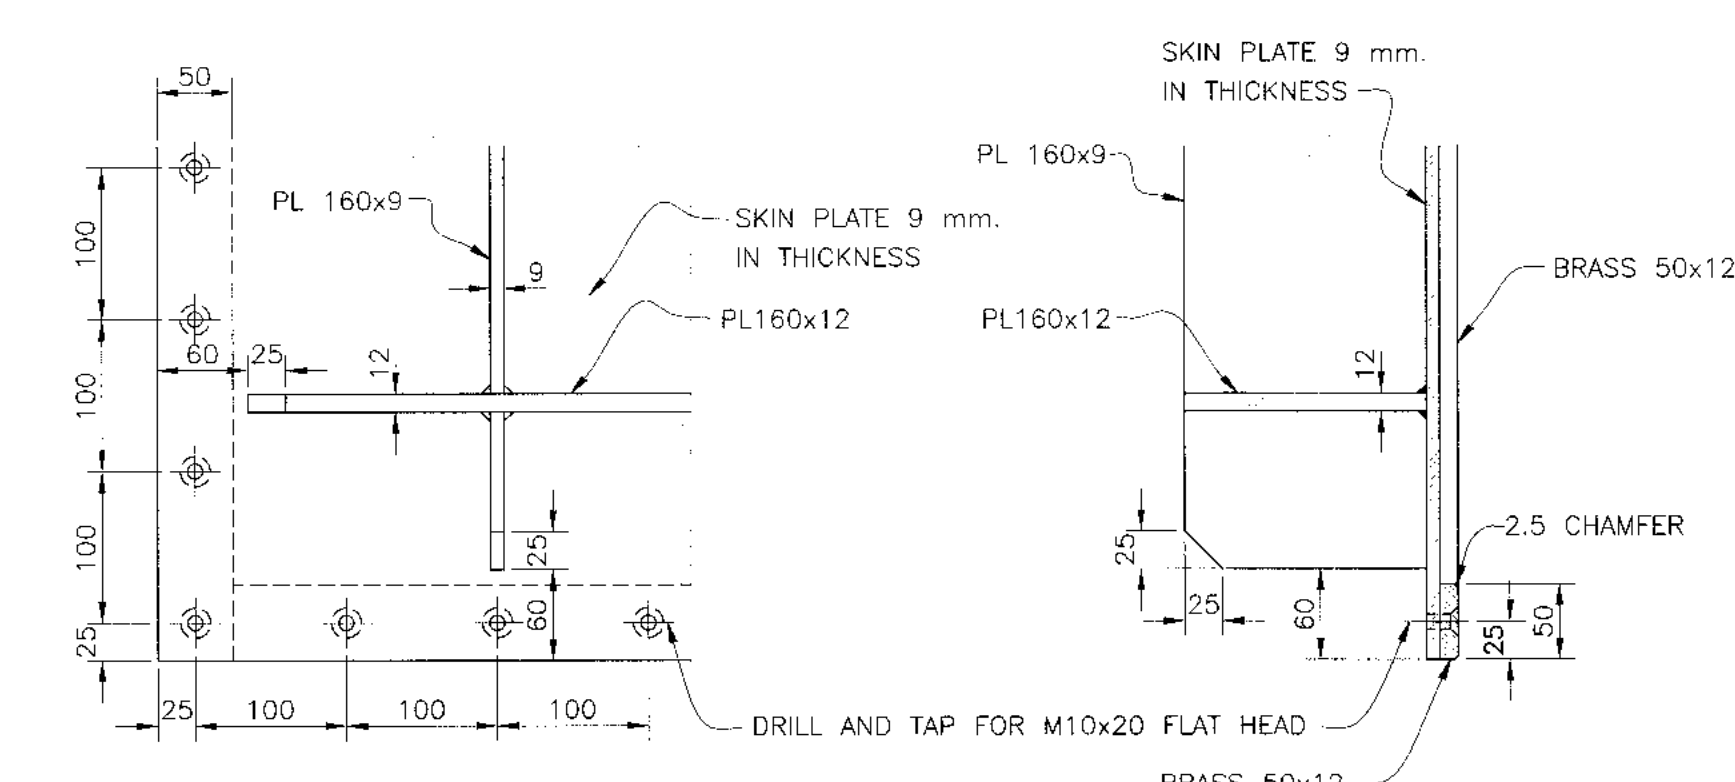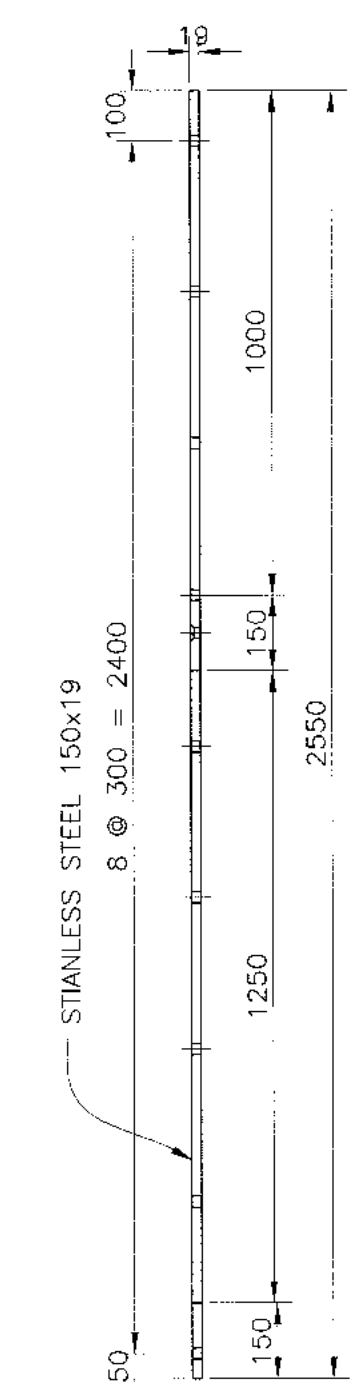


DETAIL "2"
SCALE 1:5


DETAIL "4"
SCALE 1:5

- NOTE :**
1. ALL DIMENSIONS ARE IN MILLIMETERS, UNLESS OTHERWISE SHOWN.
 2. ALL WELDING WILL BE 6 MILLIMETERS, UNLESS OTHERWISE SHOWN.
 3. ALL BOLTS AND NUTS USE ASTM A325
 4. ALL STRUCTURAL STEELS ARE JIS G 3101 SS400
 5. ALL STAINLESS STEELS PLATES ARE JIS G 4304 SUS 304

- REFERENCE DWGS :**
1. TAILRACE SECTION AND DETAIL KLP-TR-02
 2. TAILRACE 1.25x1.25 m. VERTICAL GATE INSTALLATION KLP-TR-04

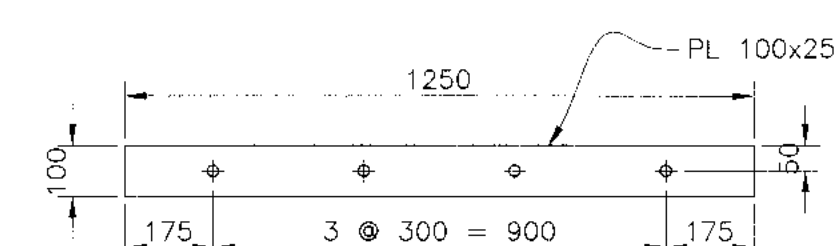

BOTTOM BAR
SCALE 1:15

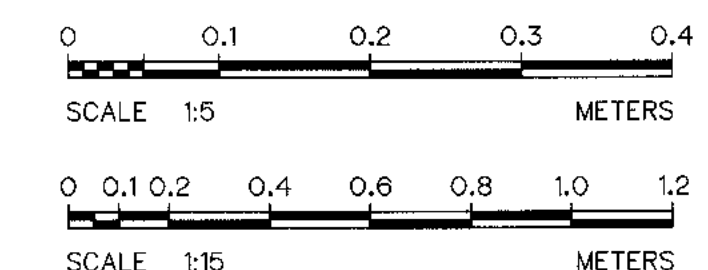

NO.	DATE	REVISIONS	CHECKED	APPROVED
3				
2				
1				

KINGDOM OF THAILAND Department of Alternative Energy Development and Efficiency MINISTRY OF ENERGY			
KLONG LAM PLOK HYDROPOWER PROJECT			
CIVIL WORKS AND TRANSMISSION LINE			
TAILRACE			
1.25x1.25 m. VERTICAL GATE DETAIL			
P&C MANAGEMENT CO.,LTD.		Department of Alternative Energy Development and Efficiency MINISTRY OF ENERGY	
DESIGNED <i>W</i> 181.29074 01.02.226		REVIEWED <i>Chant</i>	
DRAWN <i>W</i>		RECOMMENDED <i>W</i>	
CHECKED <i>W</i> 181.6226		APPROVED <i>P.Hansit</i>	
PROJECT MANAGER 08/03/2559		DRAWING NO. KLP-TR-05	
DATE		SHEET NO. 101 OF 110	